 

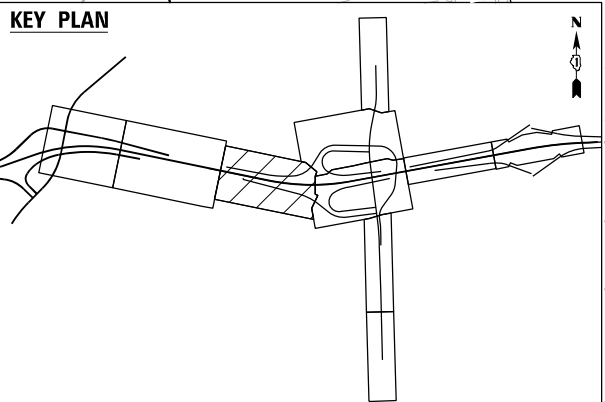


EROSION CONTROL LEGEND



- INLET FILTER
- TEMPORARY DITCH CHECK
- PERIMETER EROSION BARRIER
- INLET PROTECTION
(UTILIZING TEMP DITCH CHECKS)
- AGGREGATE (EROSION CONTROL)
FILTER FABRIC
- TEMPORARY DRAINAGE PIPE (REFER
TO TEMP. DRAIN. SCHEDULES)
- TEMPORARY EROSION CONTROL SEEDING
MULCH, METHOD 2
- TEMPORARY EROSION CONTROL SEEDING
TEMPORARY EROSION CONTROL BLANKET
- TEMP BLANKET AND SEEDING
INSTALLED IN PREVIOUS STAGE
- EROSION CONTROL DEVICES
INSTALLED IN PREVIOUS STAGE
- TEMPORARY CHAIN LINK FENCE WITH SCREENING, 8'
- TEMPORARY DRAINAGE STRUCTURE
(REFER TO TEMP. DRAIN. SCHEDULES)
- DIRECTION OF TRAFFIC
- RIPRAP (SEE DRAINAGE
PLANS FOR DETAILS)
- WORK ZONE
- PAVEMENT CONSTRUCTED
IN PREVIOUS STAGE
- TEMPORARY PAVEMENT
(PREVIOUSLY CONSTRUCTED)
- TEMPORARY PAVEMENT
(ACTIVELY CONSTRUCTING)

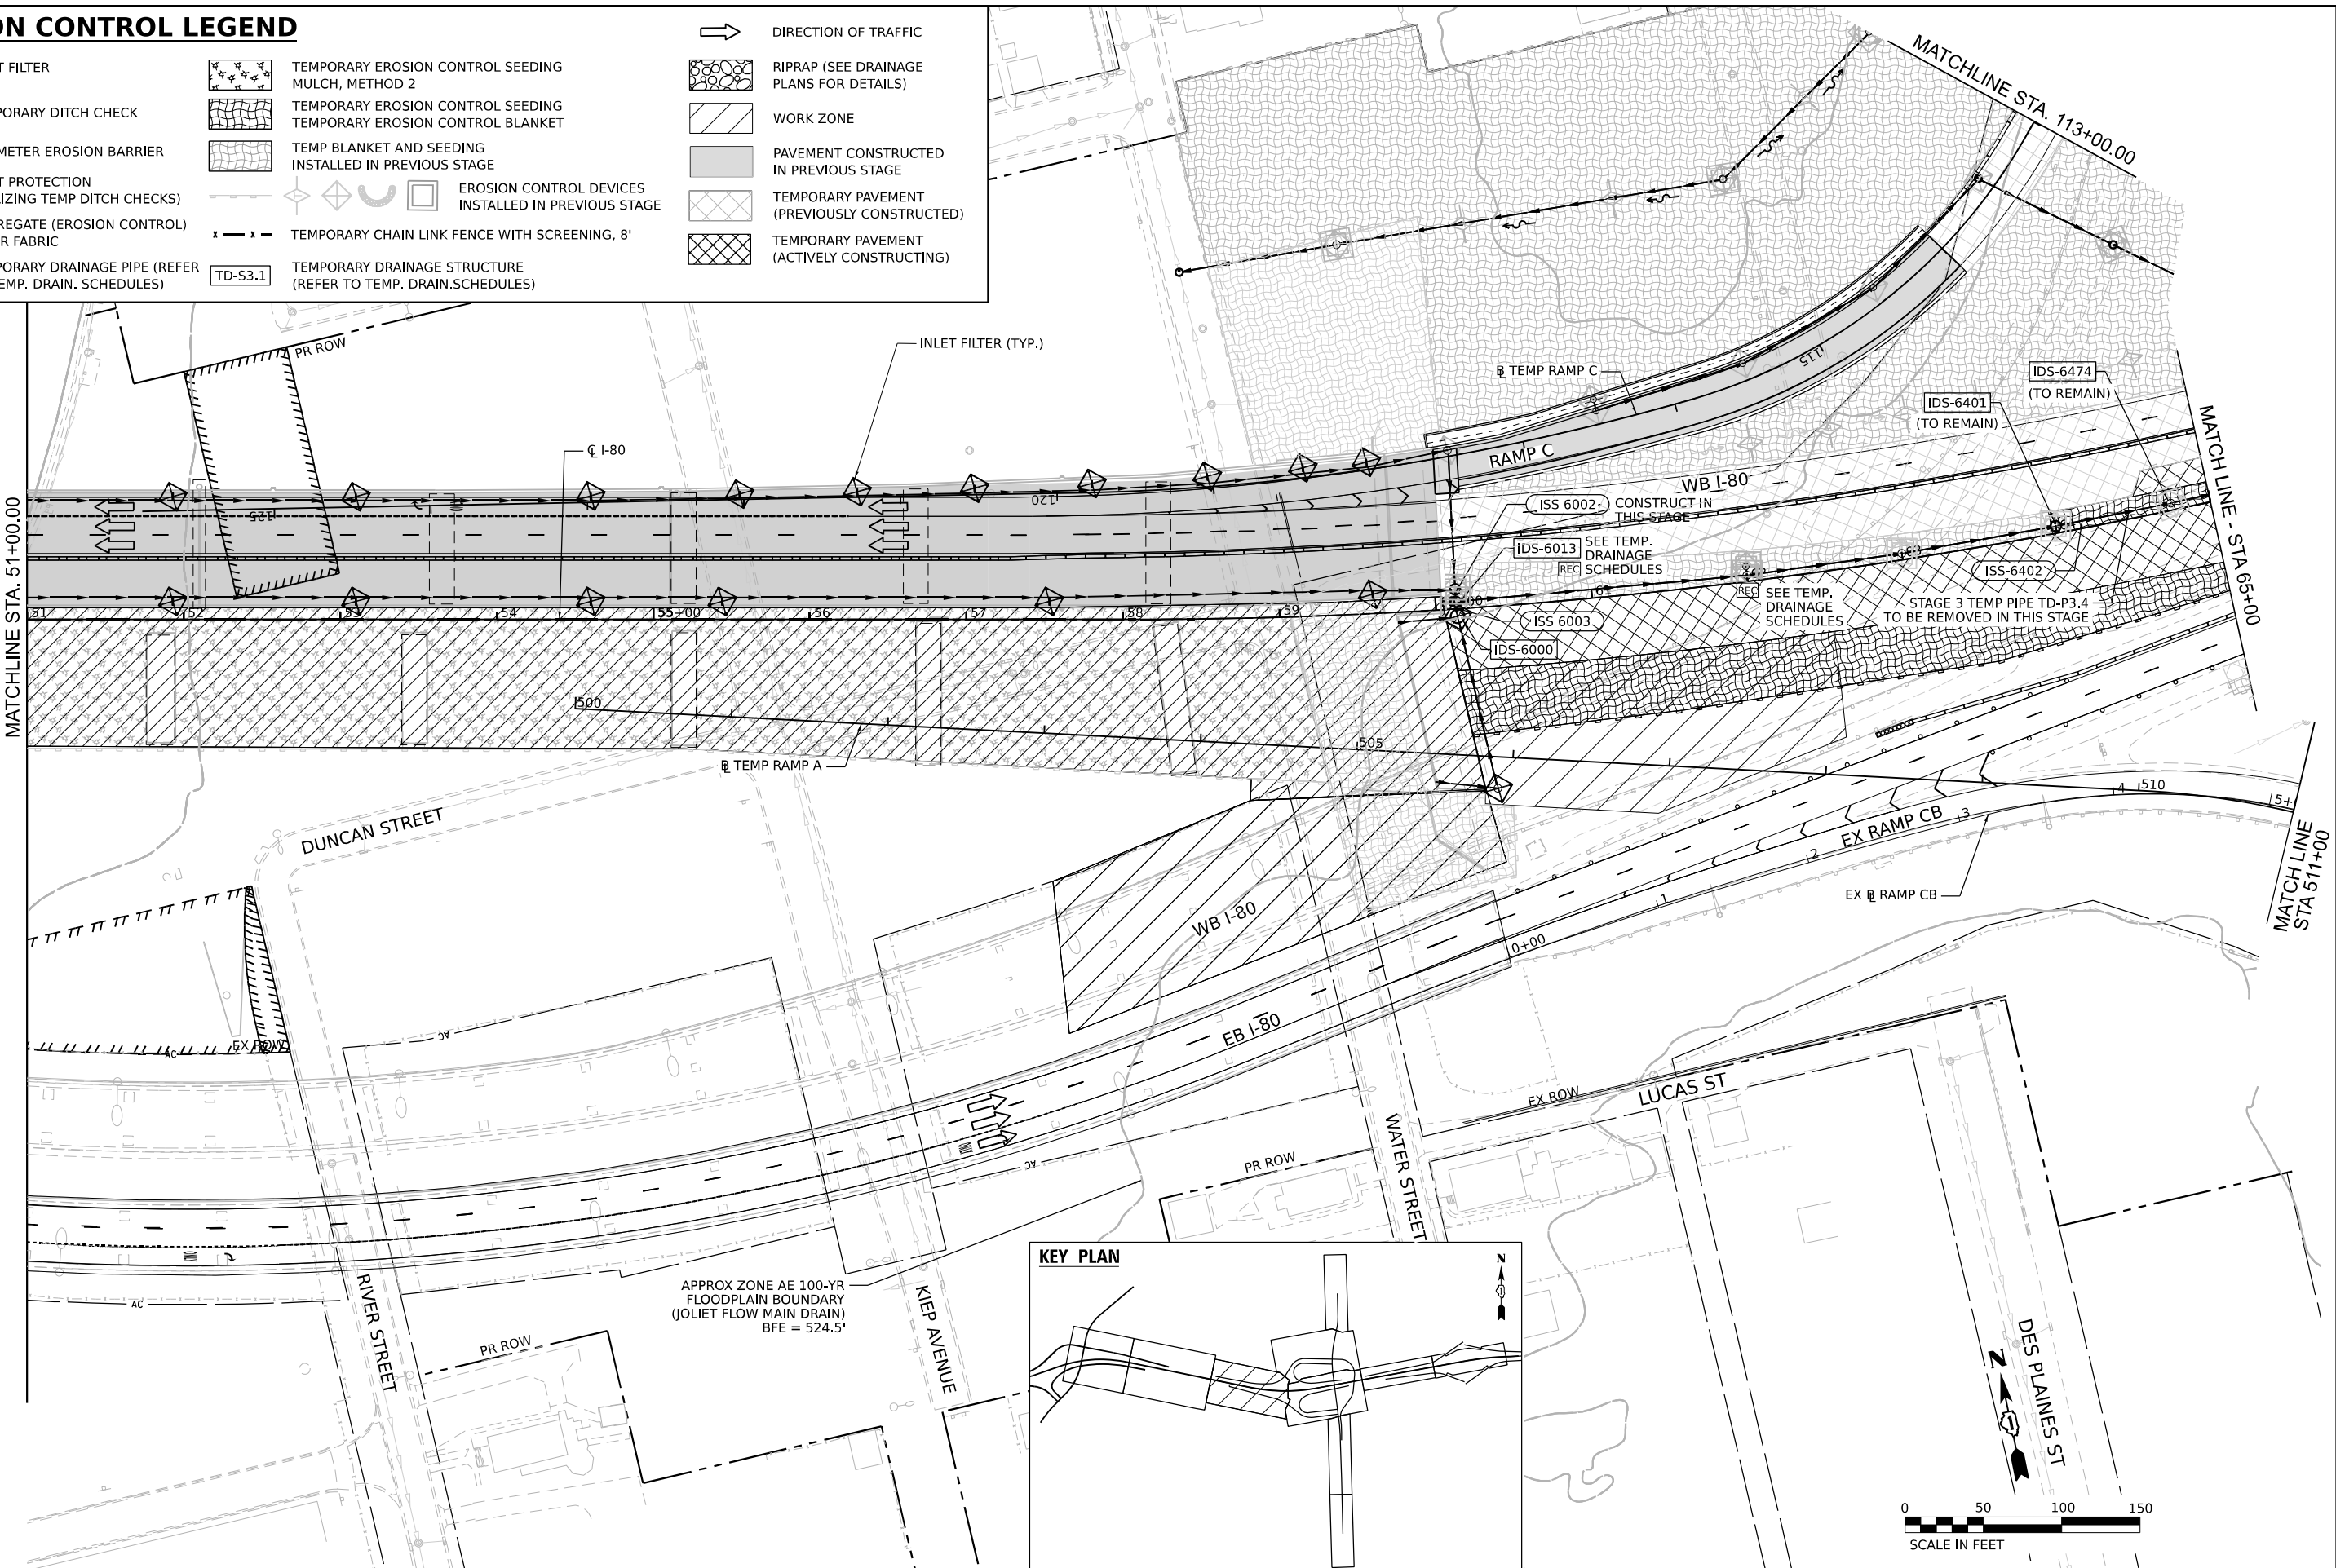

MODEL: Default
FILE NAME: p:\projects\trans\transcorp\ppl\hatched\Documents\projects_2018\CH4001\401180022\03-WSP\CAD\62R23-RB-1_Sheets\CH4001\62R23-shh-erosionstage4-3

	WSP USA Inc. 30 N. LASALLE STREET SUITE 4200 CHICAGO, IL 60602 TEL: (312) 782-8150	USER NAME = USGP718052	DESIGNED - DB	REVISED -	STATE OF ILLINOIS DEPARTMENT OF TRANSPORTATION	EROSION CONTROL PLAN				F.A.I. RTE.	SECTION	COUNTY	TOTAL SHEETS	SHEET NO.
			DRAWN - XL	REVISED -		STAGE 4				80	FAI 80 21 STRUCTURE 2	WILL	1230	301
		PLOT SCALE = 100,000 ' / in.	CHECKED - KS	REVISED -		SCALE: 1" = 50'				CONTRACT NO. 62R23				
		PLOT DATE = 11/5/2025	DATE - 11/7/2025	REVISED -		SHEET 3 OF 5 SHEETS		ILLINOIS FED. AID PROJECT						
								TO STA.						

 
MODEL: Default
FILE NAME: p:\projects\trans-stone-pw-bentley.com\trans-stone-pw\1-bentley.com\Documents\Projects_2018\CH4001\401180022\03-VS9\CAD\62R23-RB-1-Sheets\CH401\62R23-shi-erosionstage4-5

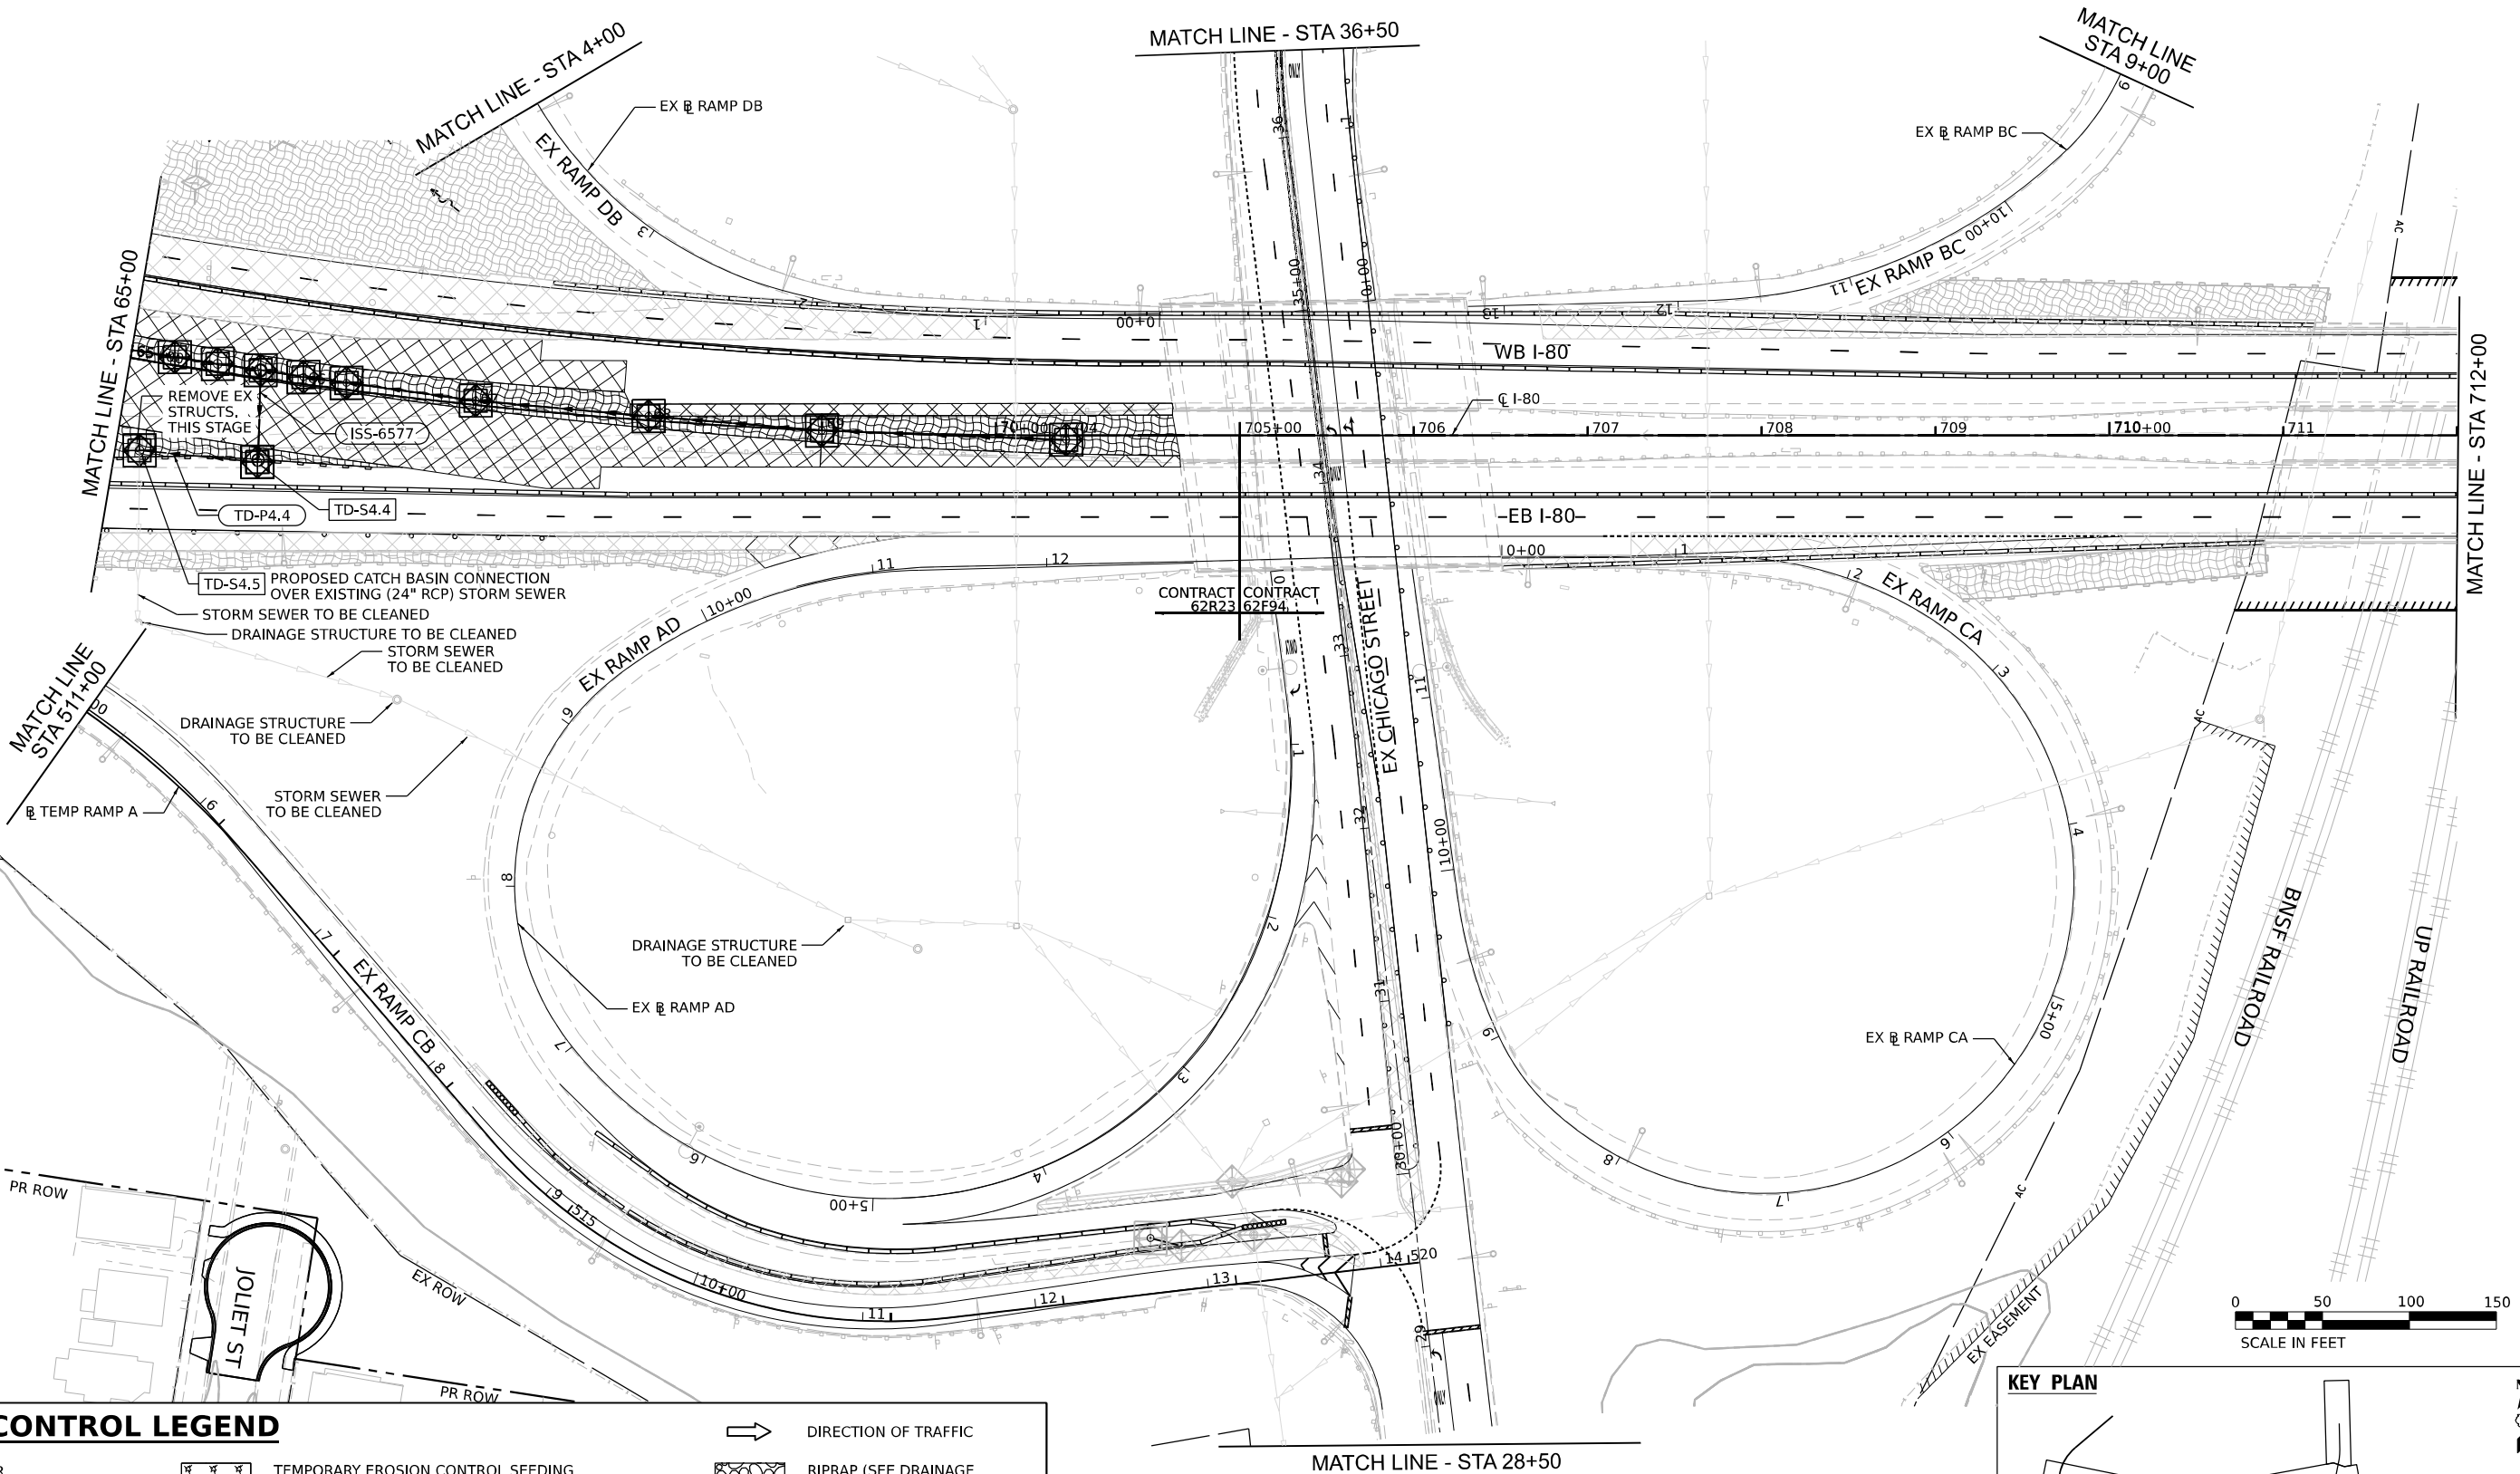

EROSION CONTROL LEGEND

	INLET FILTER		TEMPORARY EROSION CONTROL SEEDING MULCH, METHOD 2		DIRECTION OF TRAFFIC
	TEMPORARY DITCH CHECK		TEMPORARY EROSION CONTROL SEEDING TEMPORARY EROSION CONTROL BLANKET		WORK ZONE
	PERIMETER EROSION BARRIER		TEMP BLANKET AND SEEDING INSTALLED IN PREVIOUS STAGE		PAVEMENT CONSTRUCTED IN PREVIOUS STAGE
	INLET PROTECTION (UTILIZING TEMP DITCH CHECKS)		EROSION CONTROL DEVICES INSTALLED IN PREVIOUS STAGE		TEMPORARY PAVEMENT (PREVIOUSLY CONSTRUCTED)
	AGGREGATE (EROSION CONTROL) FILTER FABRIC		TEMPORARY CHAIN LINK FENCE WITH SCREENING, 8'		TEMPORARY PAVEMENT (ACTIVELY CONSTRUCTING)
	TEMPORARY DRAINAGE PIPE (REFER TO TEMP, DRAIN, SCHEDULES)		TEMPORARY DRAINAGE STRUCTURE (REFER TO TEMP, DRAIN, SCHEDULES)		

KEY PLAN

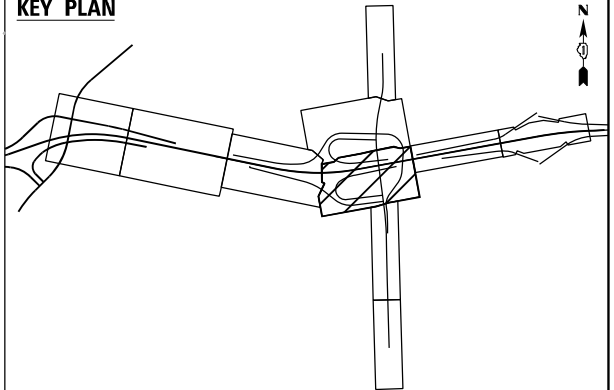


STATE OF ILLINOIS
DEPARTMENT OF TRANSPORTATION

EROSION CONTROL PLAN STAGE 4

SCALE: 1" = 50' SHEET 5 OF 5 SHEETS STA. TO STA.



F.A.I. RTE.	SECTION	COUNTY	TOTAL SHEETS	SHEET NO.
80	FAI 80 21 STRUCTURE 2	WILL	1230	303
CONTRACT NO. 62R23				
ILLINOIS FED. AID PROJECT				


	INLET FILTER		TEMPORARY DRAINAGE PIPE (REFER TO TEMP. DRAIN. SCHEDULES)		WORK ZONE		MULCH, METHOD 2
	TEMPORARY DITCH CHECK		TEMPORARY DRAINAGE STRUCTURE (REFER TO TEMP. DRAIN. SCHEDULES)		PAVEMENT CONSTRUCTED IN PREVIOUS STAGE		TEMPORARY EROSION CONTROL SEEDING
	PERIMETER EROSION BARRIER				TEMPORARY PAVEMENT (PREVIOUSLY CONSTRUCTED)		RIPRAP (SEE DRAINAGE PLANS FOR DETAILS)
	TEMPORARY CHAIN LINK FENCE WITH SCREENING, 8'		AGGREGATE (EROSION CONTROL) FILTER FABRIC		TEMPORARY PAVEMENT (ACTIVELY CONSTRUCTING)		TEMP BLANKET AND SEEDING INSTALLED IN PREVIOUS STAGE
	INLET PROTECTION (UTILIZING TEMP DITCH CHECKS)		EROSION CONTROL DEVICES INSTALLED IN PREVIOUS STAGE				DIRECTION OF TRAFFIC

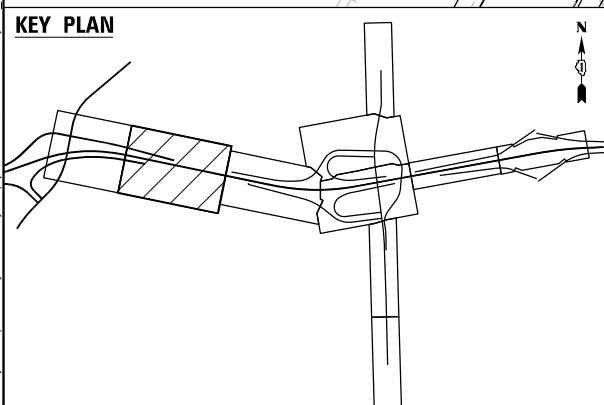

 WSP USA INC. 30 N. LASALLE STREET SUITE 4200 CHICAGO, IL 60602 TEL: (312) 782-4150	USER NAME = USGP718052	DESIGNED - DB	REVISED -	STATE OF ILLINOIS DEPARTMENT OF TRANSPORTATION	EROSION CONTROL PLAN STAGE 5					F.A.I. RTE.	SECTION	COUNTY	TOTAL SHEETS	SHEET NO.
		DRAWN - XL	REVISED -		80	FAI 80 21 STRUCTURE 2	WILL	1230	305					
	PLOT SCALE = 100,000 ' / in.	CHECKED - KS	REVISED -		CONTRACT NO. 62R23									
	PLOT DATE = 11/5/2025	DATE - 11/7/2025	REVISED -											
	SCALE: 1" = 50'					SHEET 2 OF 5 SHEETS	STA.	TO STA.						


	INLET FILTER		TEMPORARY EROSION CONTROL SEEDING MULCH, METHOD 2		RIPRAP (SEE DRAINAGE PLANS FOR DETAILS)
	TEMPORARY DITCH CHECK		TEMPORARY EROSION CONTROL SEEDING TEMPORARY EROSION CONTROL BLANKET		WORK ZONE
	PERIMETER EROSION BARRIER		TEMP BLANKET AND SEEDING INSTALLED IN PREVIOUS STAGE		PAVEMENT CONSTRUCTED IN PREVIOUS STAGE
	INLET PROTECTION (UTILIZING TEMP DITCH CHECKS)		EROSION CONTROL DEVICES INSTALLED IN PREVIOUS STAGE		TEMPORARY PAVEMENT (PREVIOUSLY CONSTRUCTED)
	AGGREGATE (EROSION CONTROL) FILTER FABRIC		TEMPORARY CHAIN LINK FENCE WITH SCREENING, 8'		TEMPORARY PAVEMENT (ACTIVELY CONSTRUCTING)
	TEMPORARY DRAINAGE PIPE (REFER TO TEMP. DRAIN. SCHEDULES)		TEMPORARY DRAINAGE STRUCTURE (REFER TO TEMP. DRAIN. SCHEDULES)		

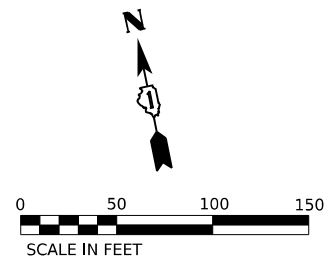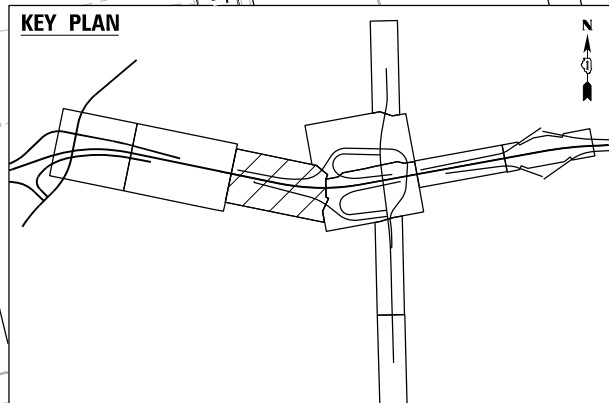


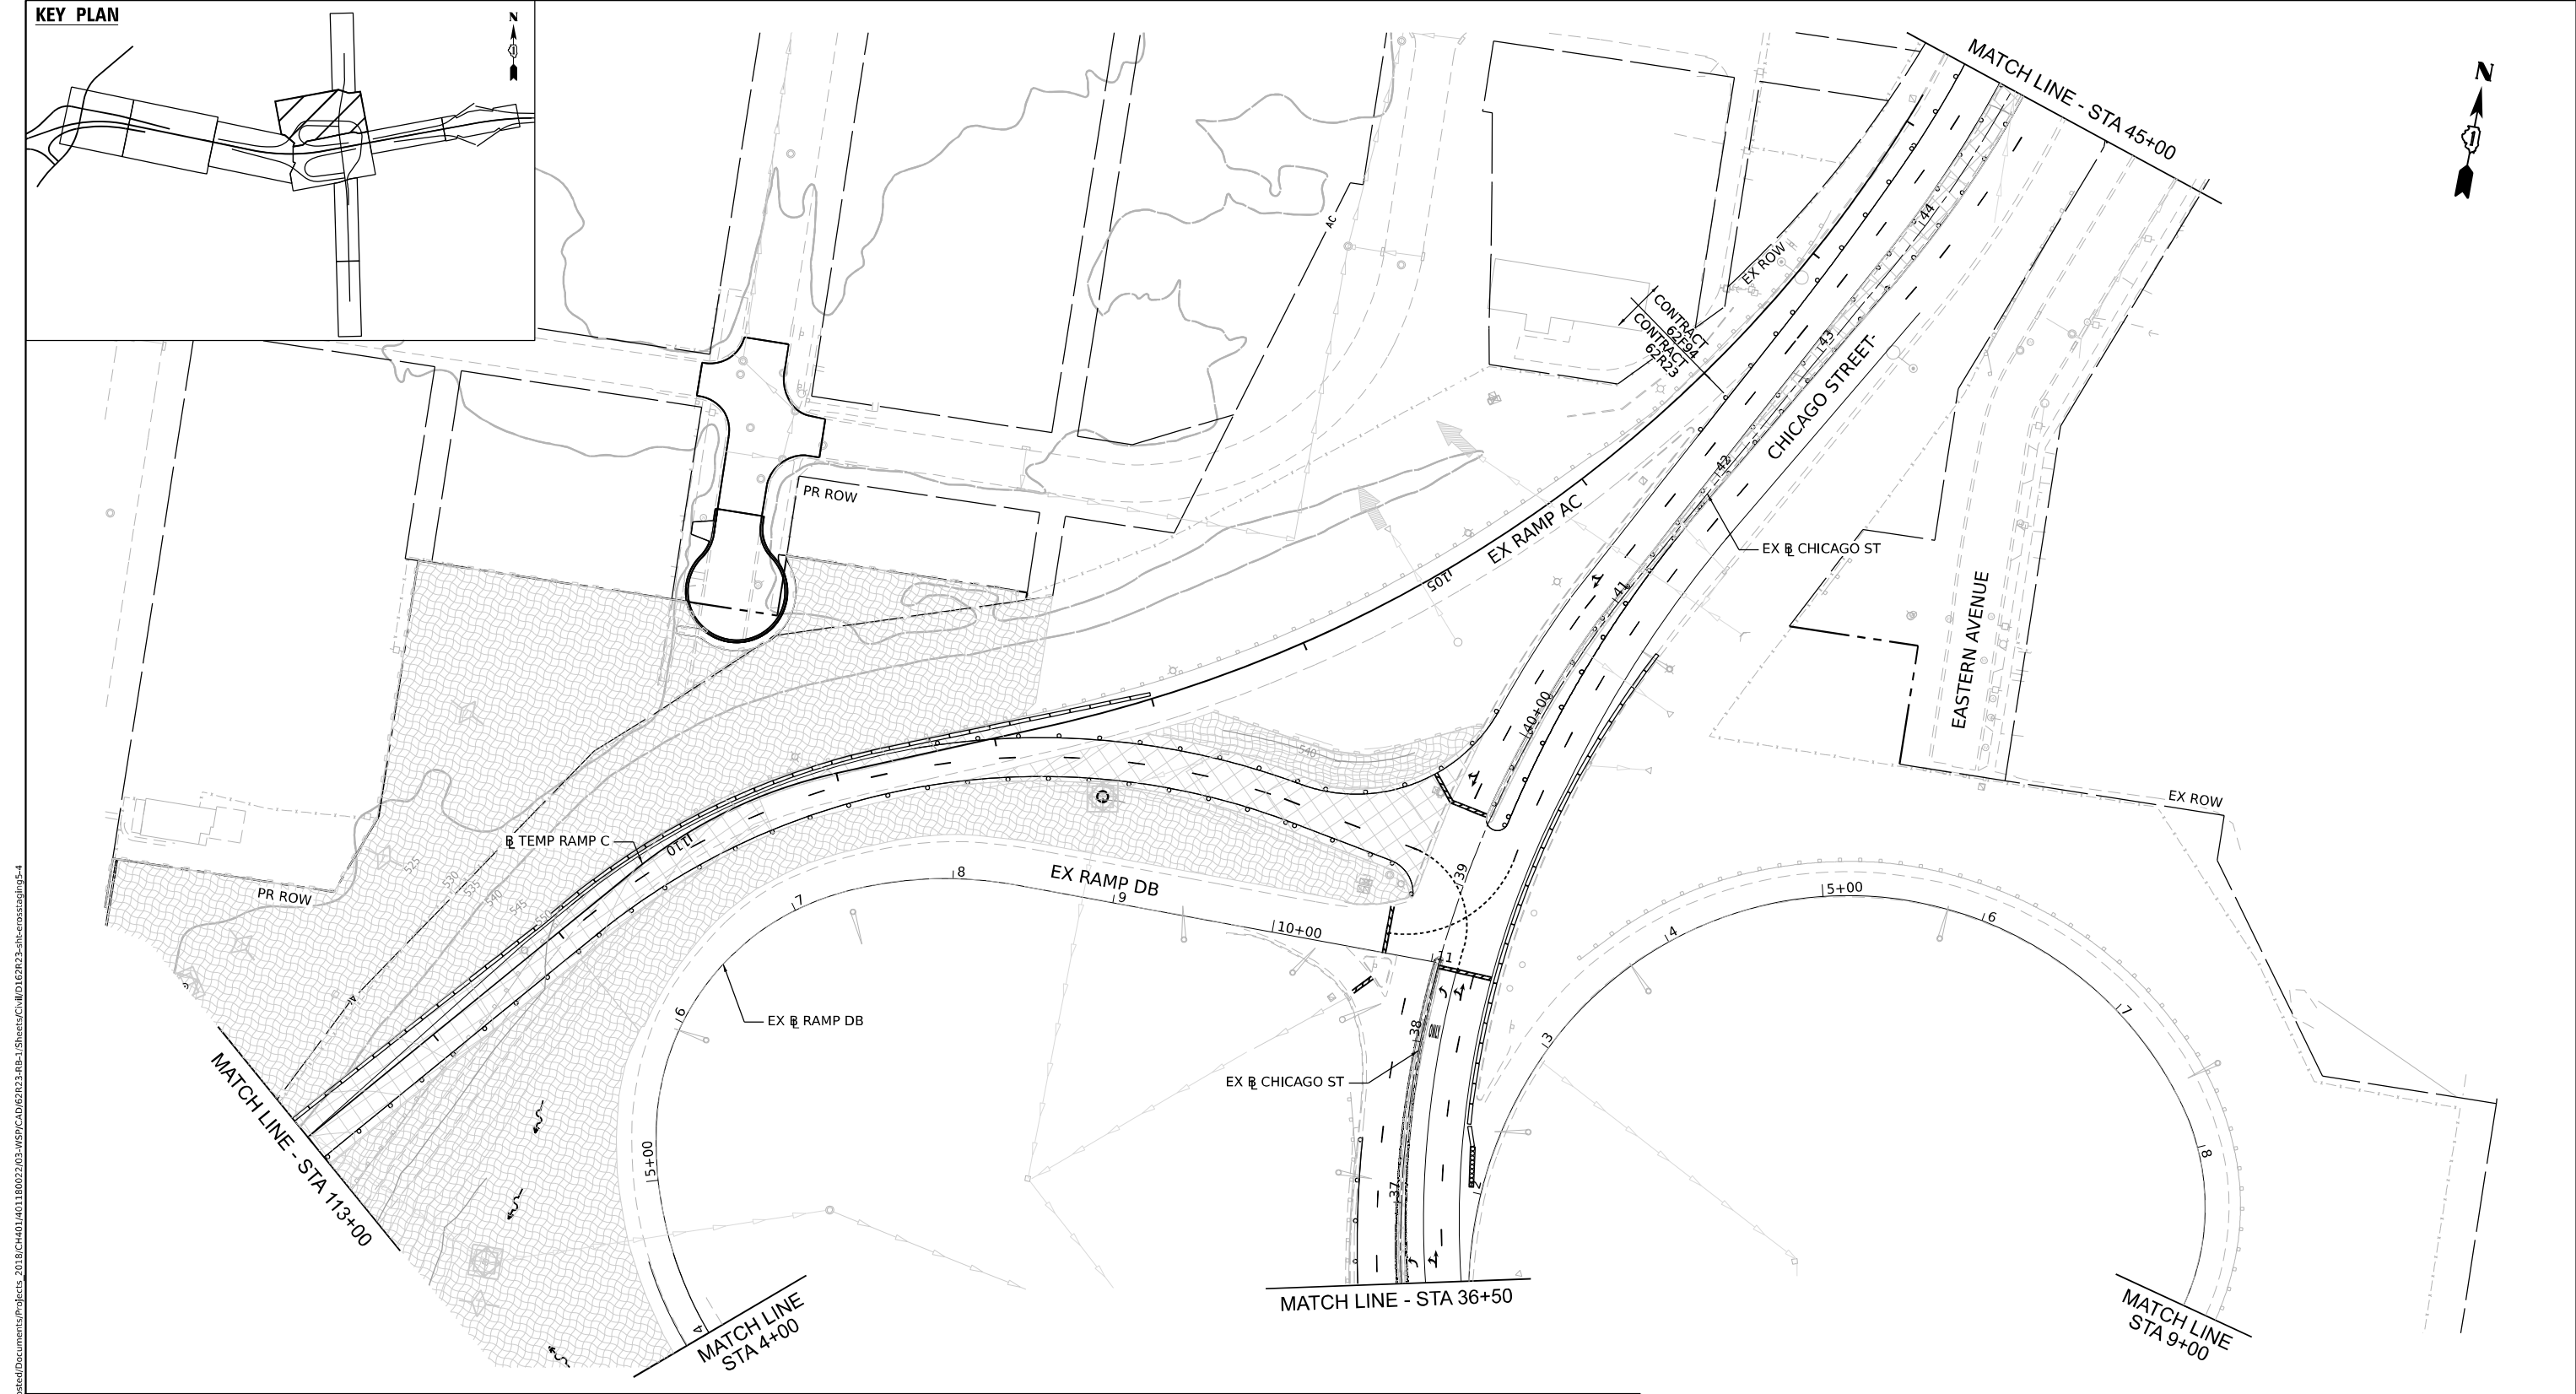

EROSION CONTROL LEGEND

 - INLET FILTER
- TEMPORARY DITCH CHECK
- PERIMETER EROSION BARRIER
- TEMPORARY CHAIN LINK FENCE WITH SCREENING, 8'
- INLET PROTECTION (UTILIZING TEMP DITCH CHECKS)
- TD-P3.1 TEMPORARY DRAINAGE PIPE (REFER TO TEMP. DRAIN. SCHEDULES)
- TD-S3.1 TEMPORARY DRAINAGE STRUCTURE (REFER TO TEMP. DRAIN. SCHEDULES)
- AGGREGATE (EROSION CONTROL) FILTER FABRIC
- EROSION CONTROL DEVICES INSTALLED IN PREVIOUS STAGE
- WORK ZONE
- PAVEMENT CONSTRUCTED IN PREVIOUS STAGE
- TEMPORARY PAVEMENT (PREVIOUSLY CONSTRUCTED)
- TEMPORARY PAVEMENT (ACTIVELY CONSTRUCTING)
- TEMPORARY EROSION CONTROL SEEDING MULCH, METHOD 2
- TEMPORARY EROSION CONTROL SEEDING TEMPORARY EROSION CONTROL BLANKET
- RIPRAP (SEE DRAINAGE PLANS FOR DETAILS)
- TEMP BLANKET AND SEEDING INSTALLED IN PREVIOUS STAGE
- DIRECTION OF TRAFFIC



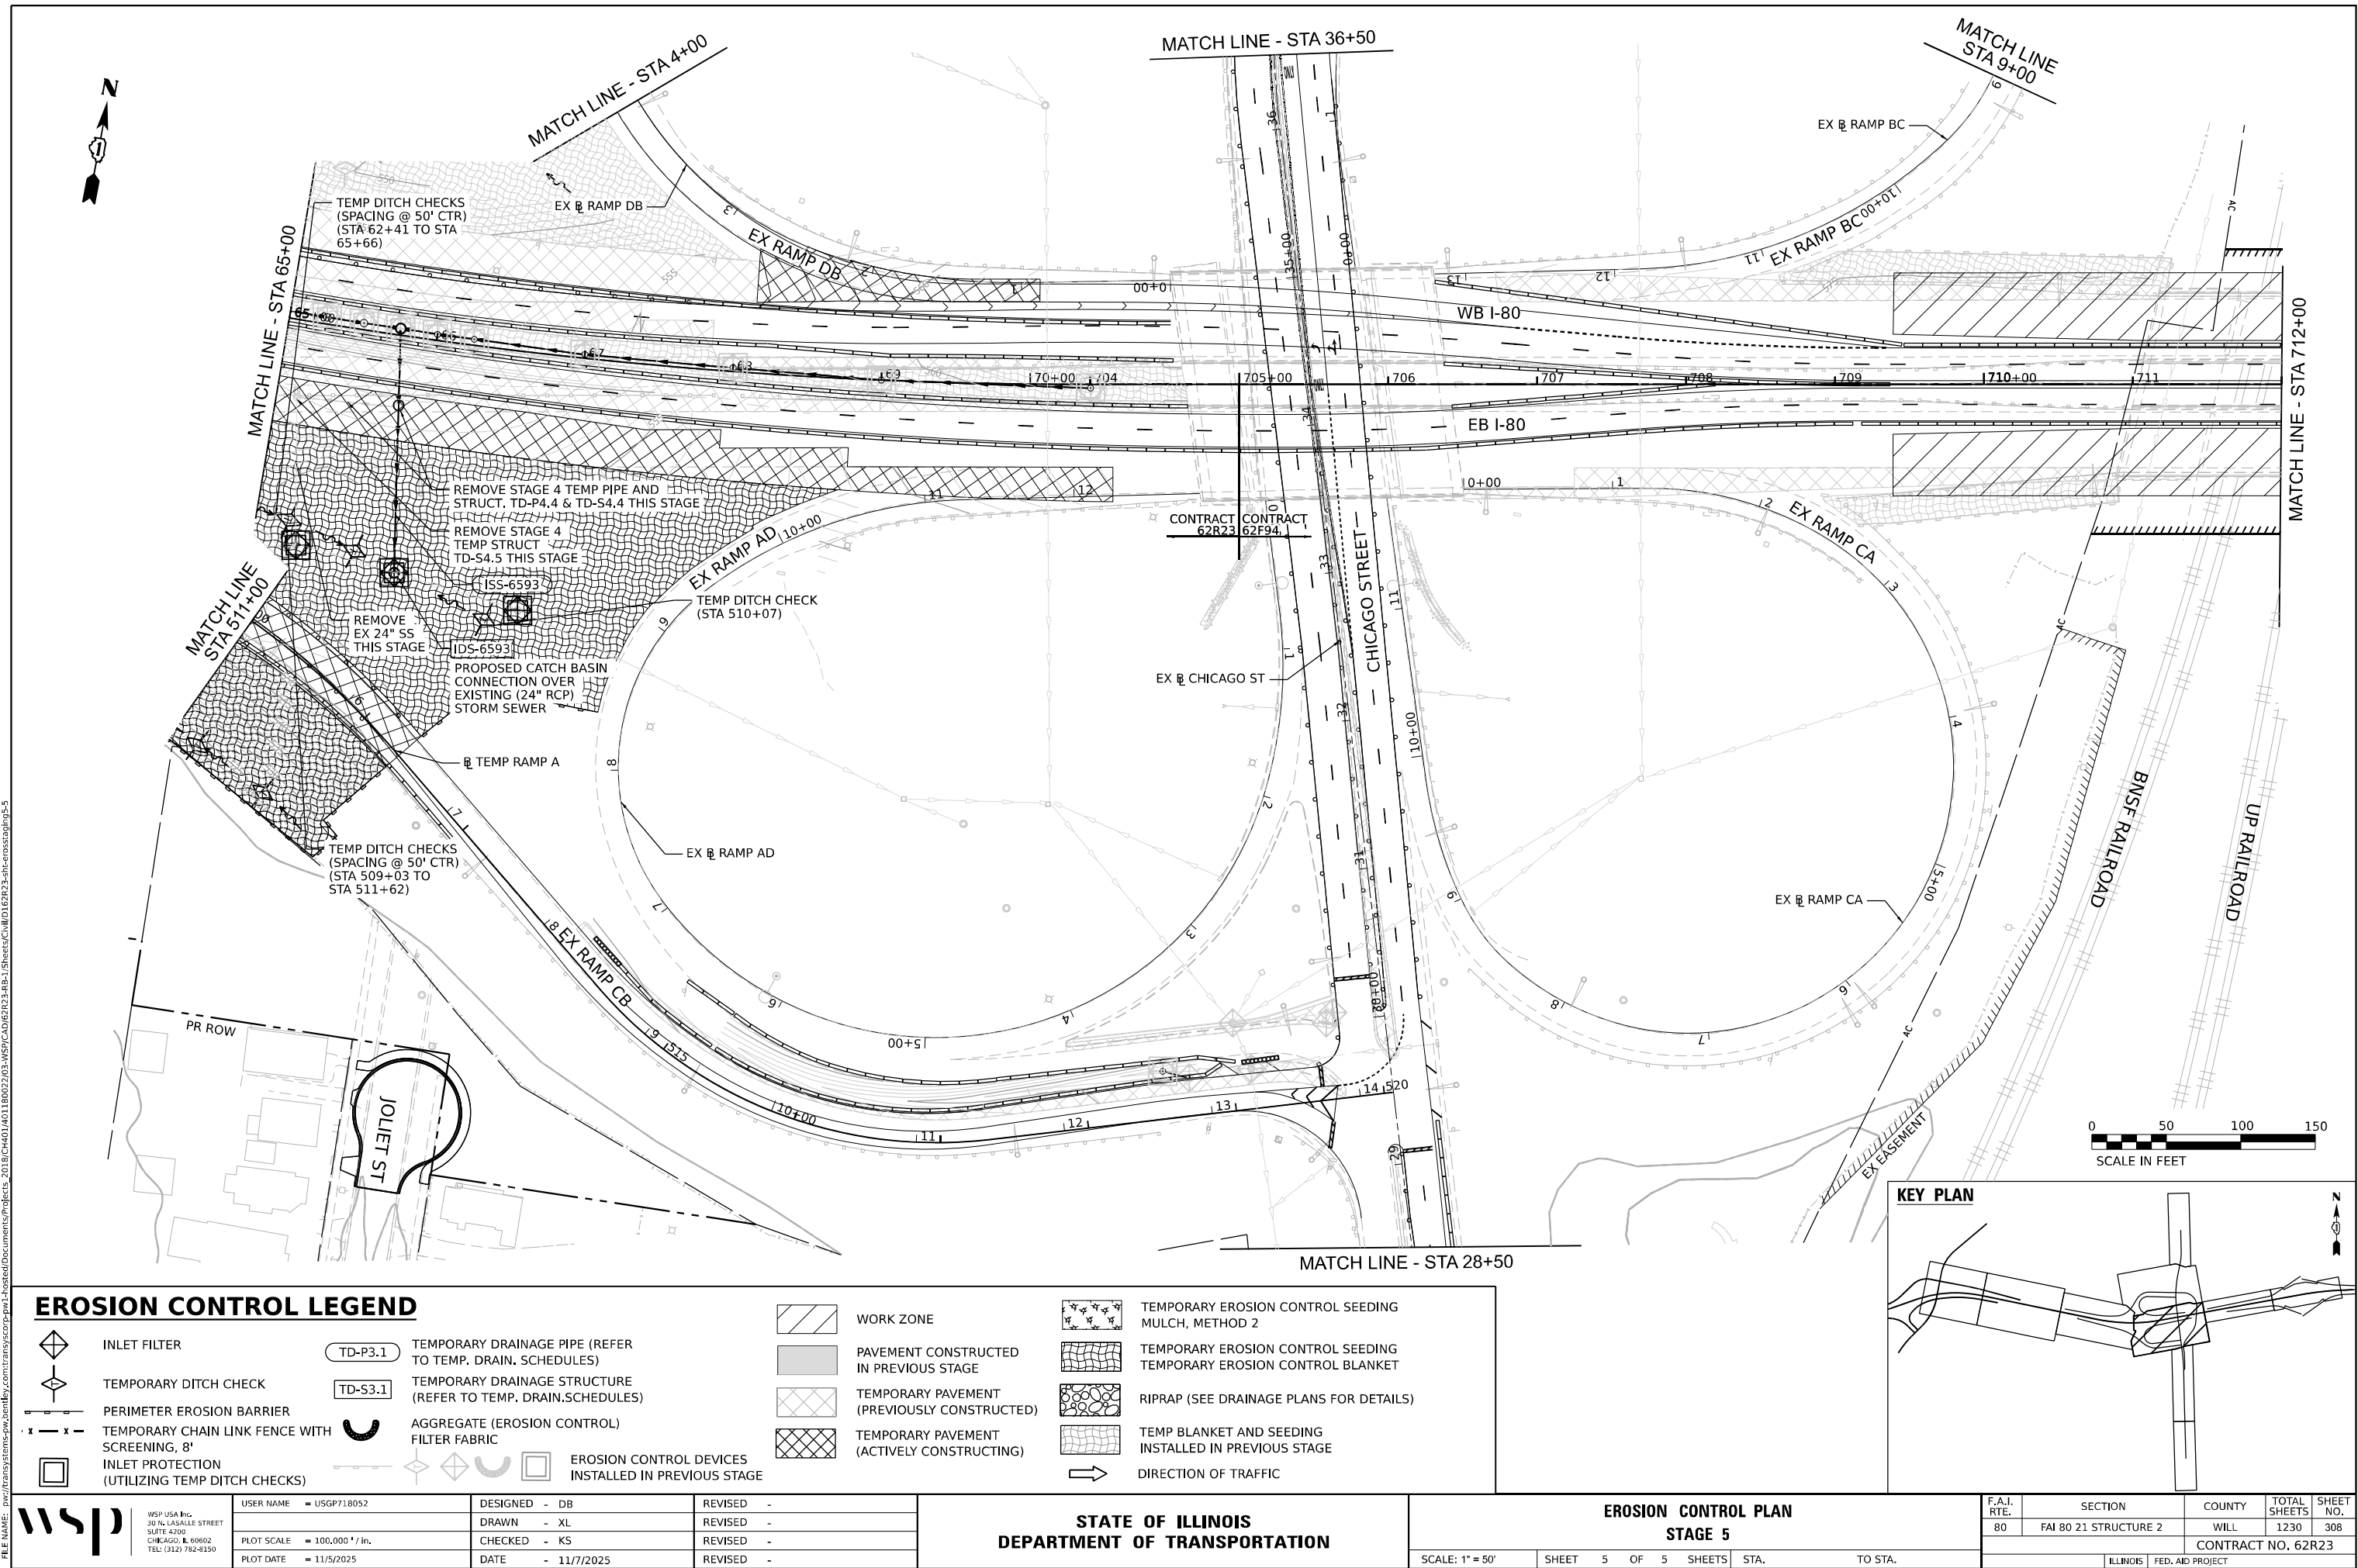

EROSION CONTROL LEGEND

- 
INLET FILTER


TEMPORARY DITCH CHECK


PERIMETER EROSION BARRIER


RIPRAP
(SEE DRAINAGE PLANS FOR DETAILS)
- 
TEMPORARY EROSION CONTROL SEEDING
MULCH, METHOD 2


TEMPORARY EROSION CONTROL SEEDING
EROSION CONTROL BLANKET




TEMPORARY EROSION CONTROL SEEDING
HEAVY DUTY EROSION CONTROL BLANKET
- 
TEMPORARY SEDIMENT BASIN


INLET PROTECTION
(UTILIZING TEMP DITCH CHECKS)



AGGREGATE (EROSION CONTROL)
FILTER FABRIC


PAVEMENT CONSTRUCTED IN CURRENT
STAGE OR PREVIOUS STAGE


TEMPORARY PAVEMENT

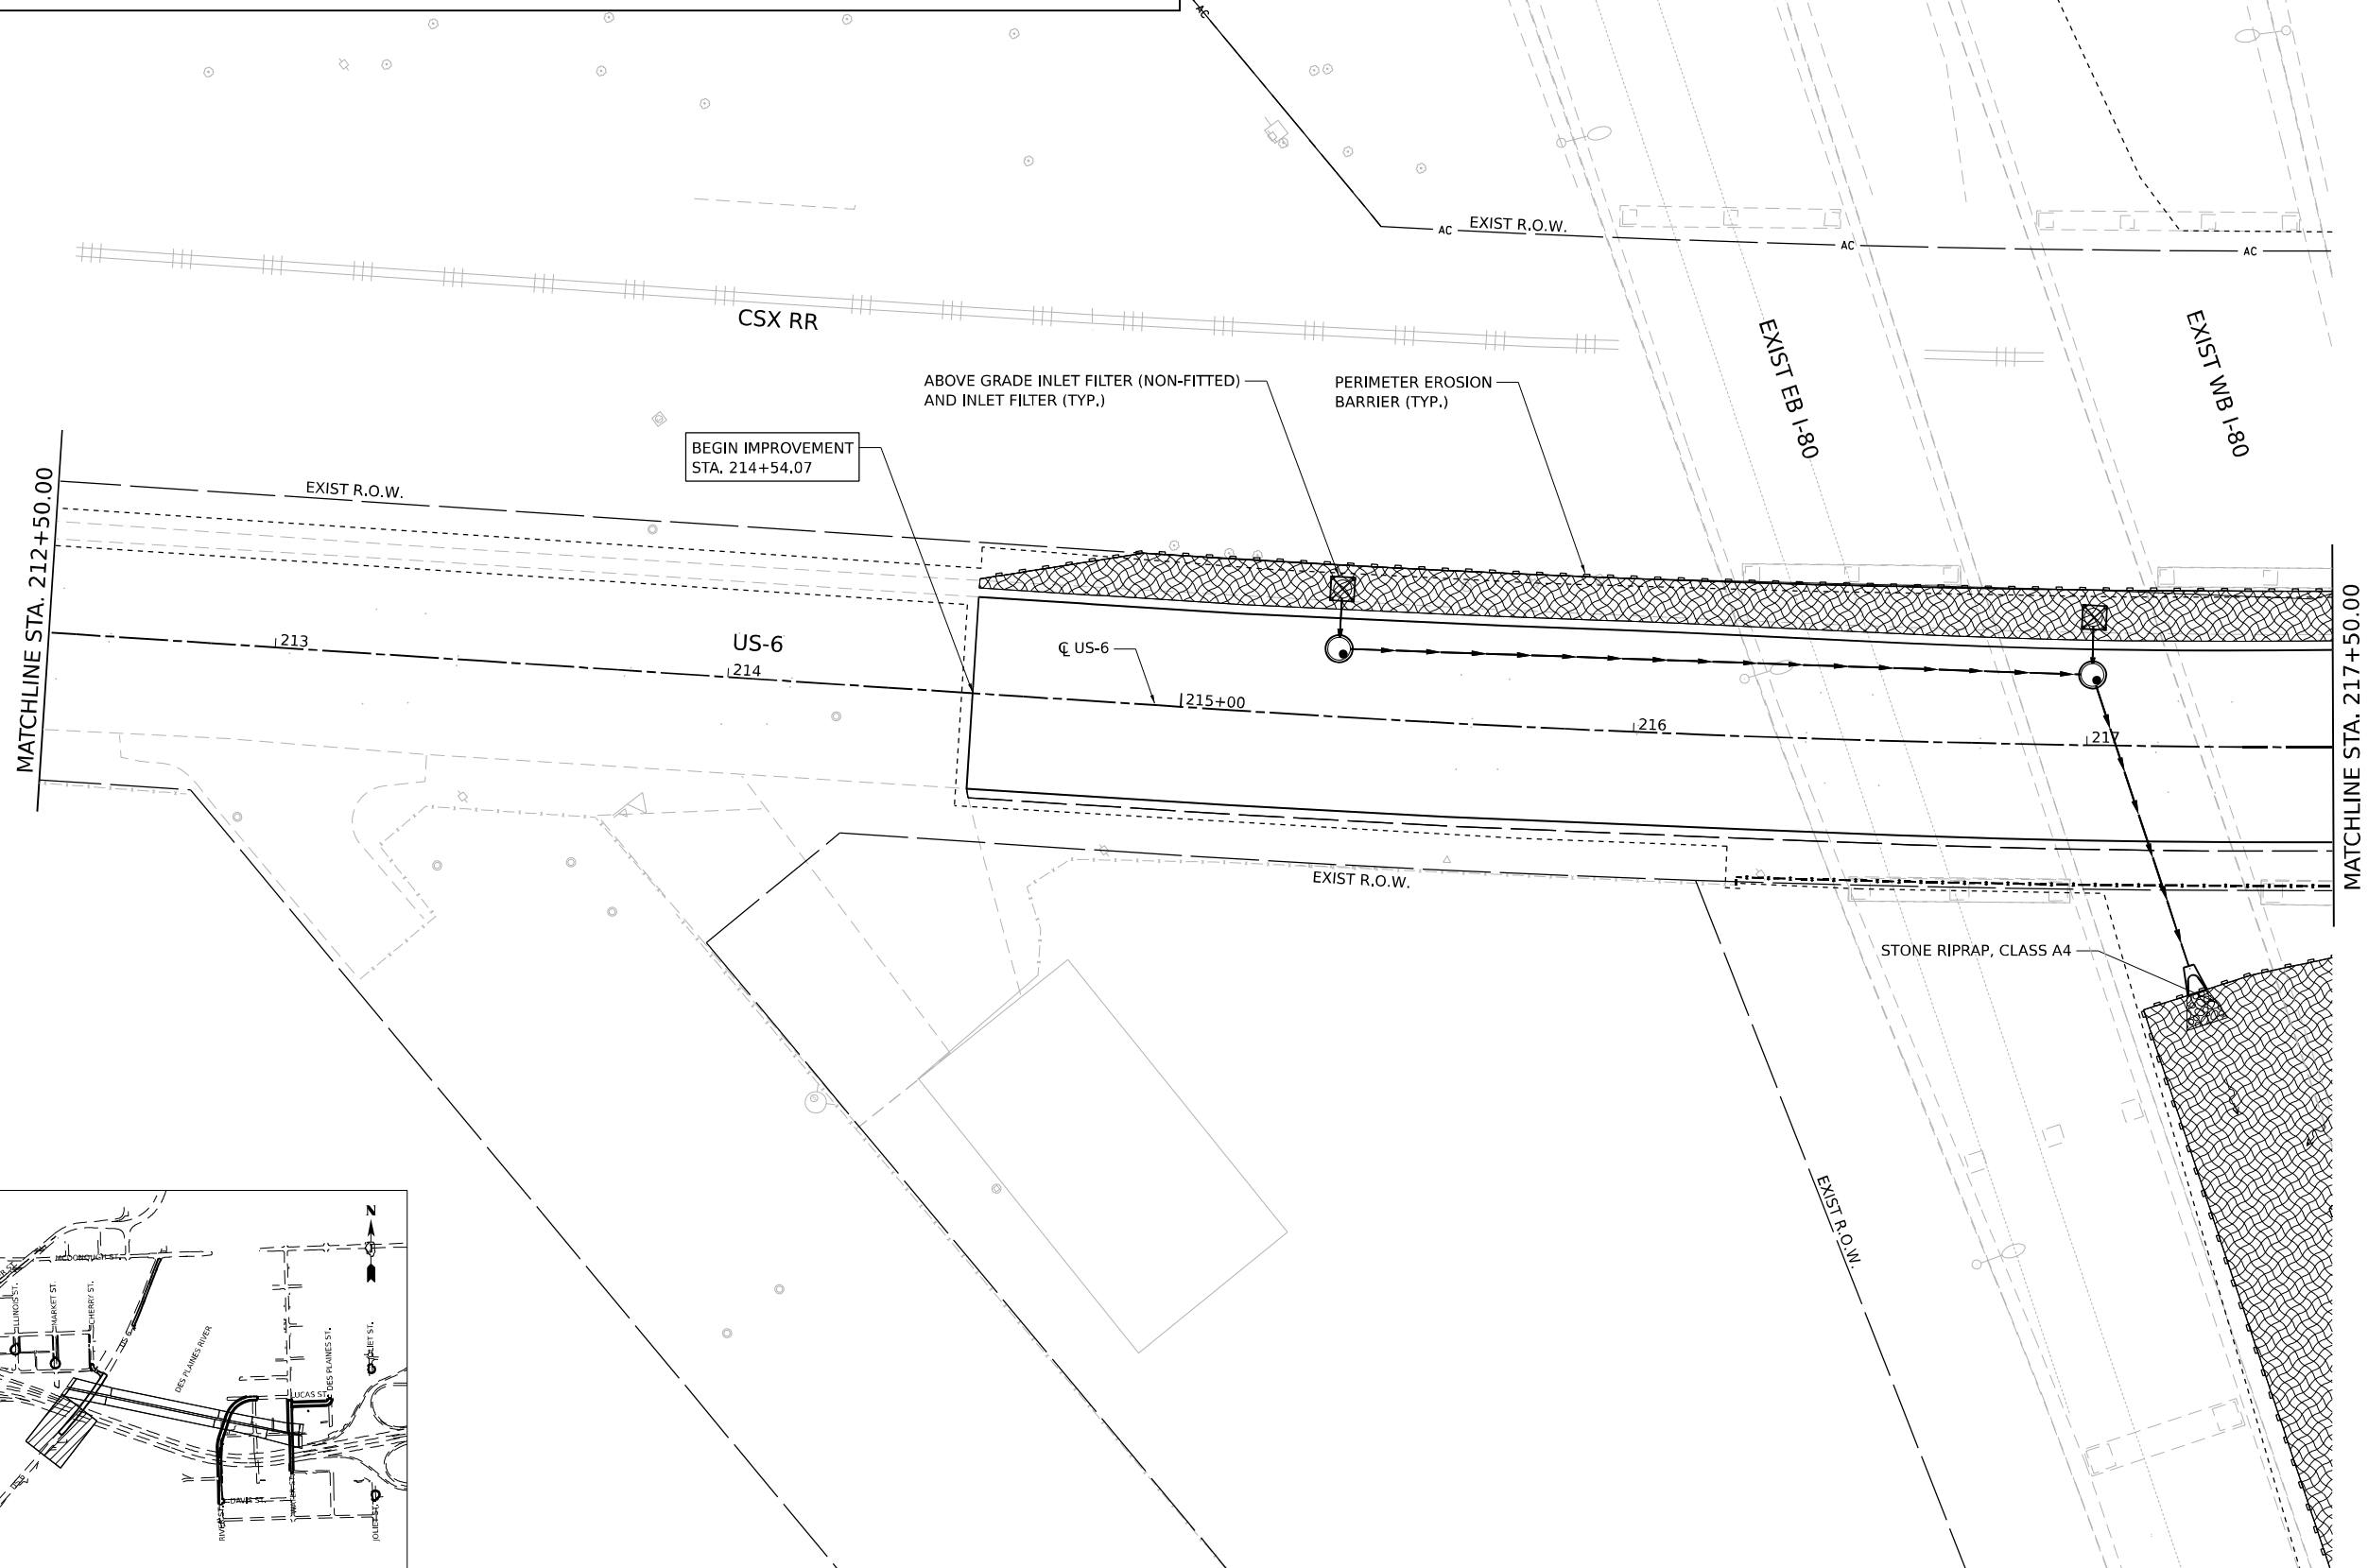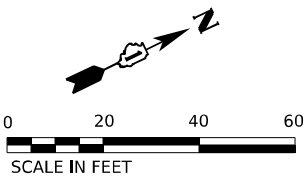

KEY PLAN

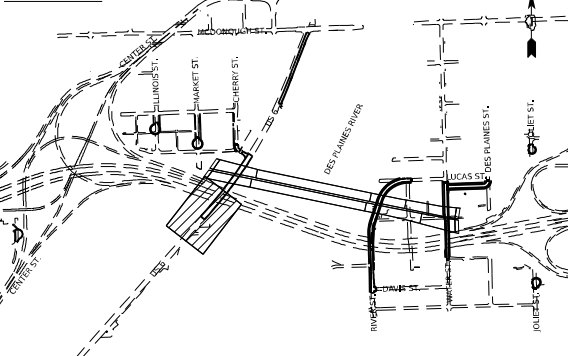

WSP USA INC.
30 N. LASALLE STREET
SUITE 4200
CHICAGO, IL 60602
TEL: (312) 782-8150

USER NAME	= USHC706648
DESIGNED	- CC
DRAWN	- XL
PLOT SCALE	= 40,000' / in.
PLLOT DATE	= 11/6/2025
CHECKED	- DB
DATE	- 11/7/2025


REVISED	-
REVISED	-
REVISED	-
REVISED	-

STATE OF ILLINOIS
DEPARTMENT OF TRANSPORTATION

EROSION CONTROL PLAN
US-6

SCALE: 1"=20' SHEET 1 OF 12 SHEETS STA. TO STA.



F.A.I. RTE.	SECTION	COUNTY	TOTAL SHEETS	SHEET NO.
80	FAI 80 21 STRUCTURE 2	WILL	1230	309
CONTRACT NO. 62R23				
ILLINOIS FED. AID PROJECT				

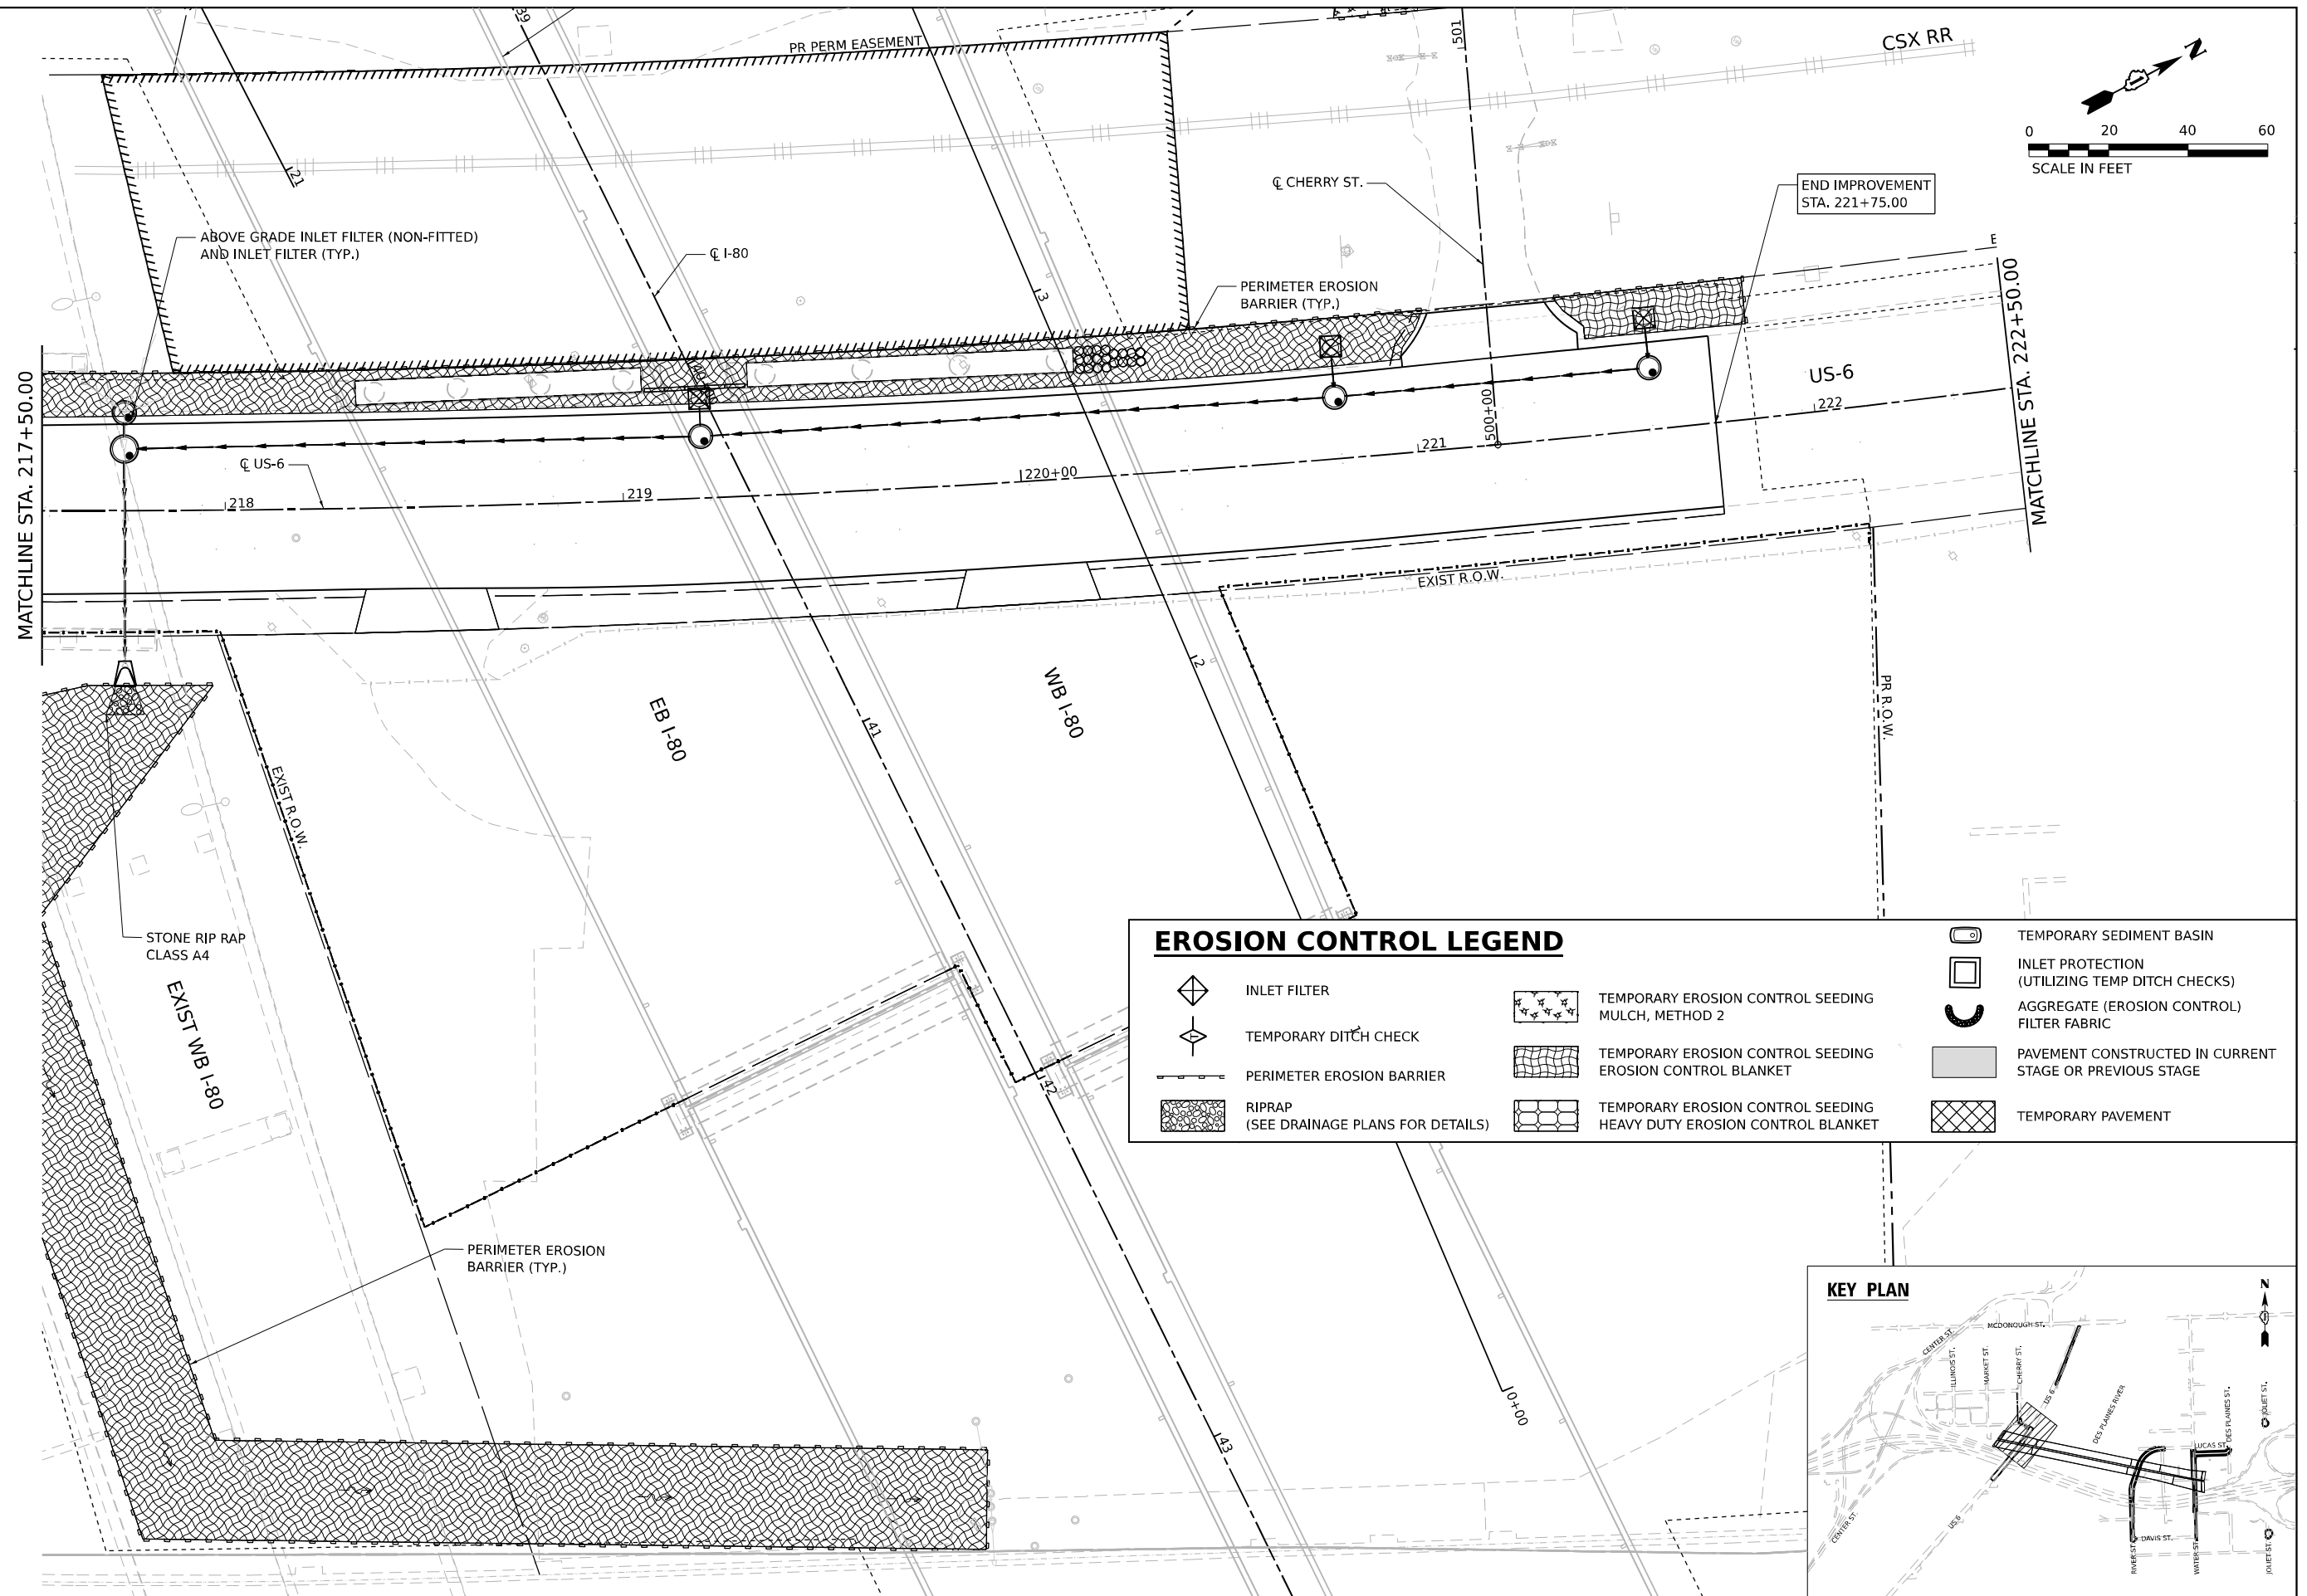

EROSION CONTROL LEGEND

 INLET FILTER	 TEMPORARY EROSION CONTROL SEEDING MULCH, METHOD 2	 TEMPORARY SEDIMENT BASIN
 TEMPORARY DITCH CHECK	 TEMPORARY EROSION CONTROL SEEDING EROSION CONTROL BLANKET	 INLET PROTECTION (UTILIZING TEMP DITCH CHECKS)
 PERIMETER EROSION BARRIER	 TEMPORARY EROSION CONTROL SEEDING HEAVY DUTY EROSION CONTROL BLANKET	 AGGREGATE (EROSION CONTROL) FILTER FABRIC
 RIPRAP (SEE DRAINAGE PLANS FOR DETAILS)		 PAVEMENT CONSTRUCTED IN CURRENT STAGE OR PREVIOUS STAGE
		 TEMPORARY PAVEMENT

Model: Default
File Name: p:\projects\trans\scorp\p1\hatched\Documents\Projects_2018\CH4001401180022\03-MS9\CAD\62R23-shr-eros.cad\Roads-plan13.dgn

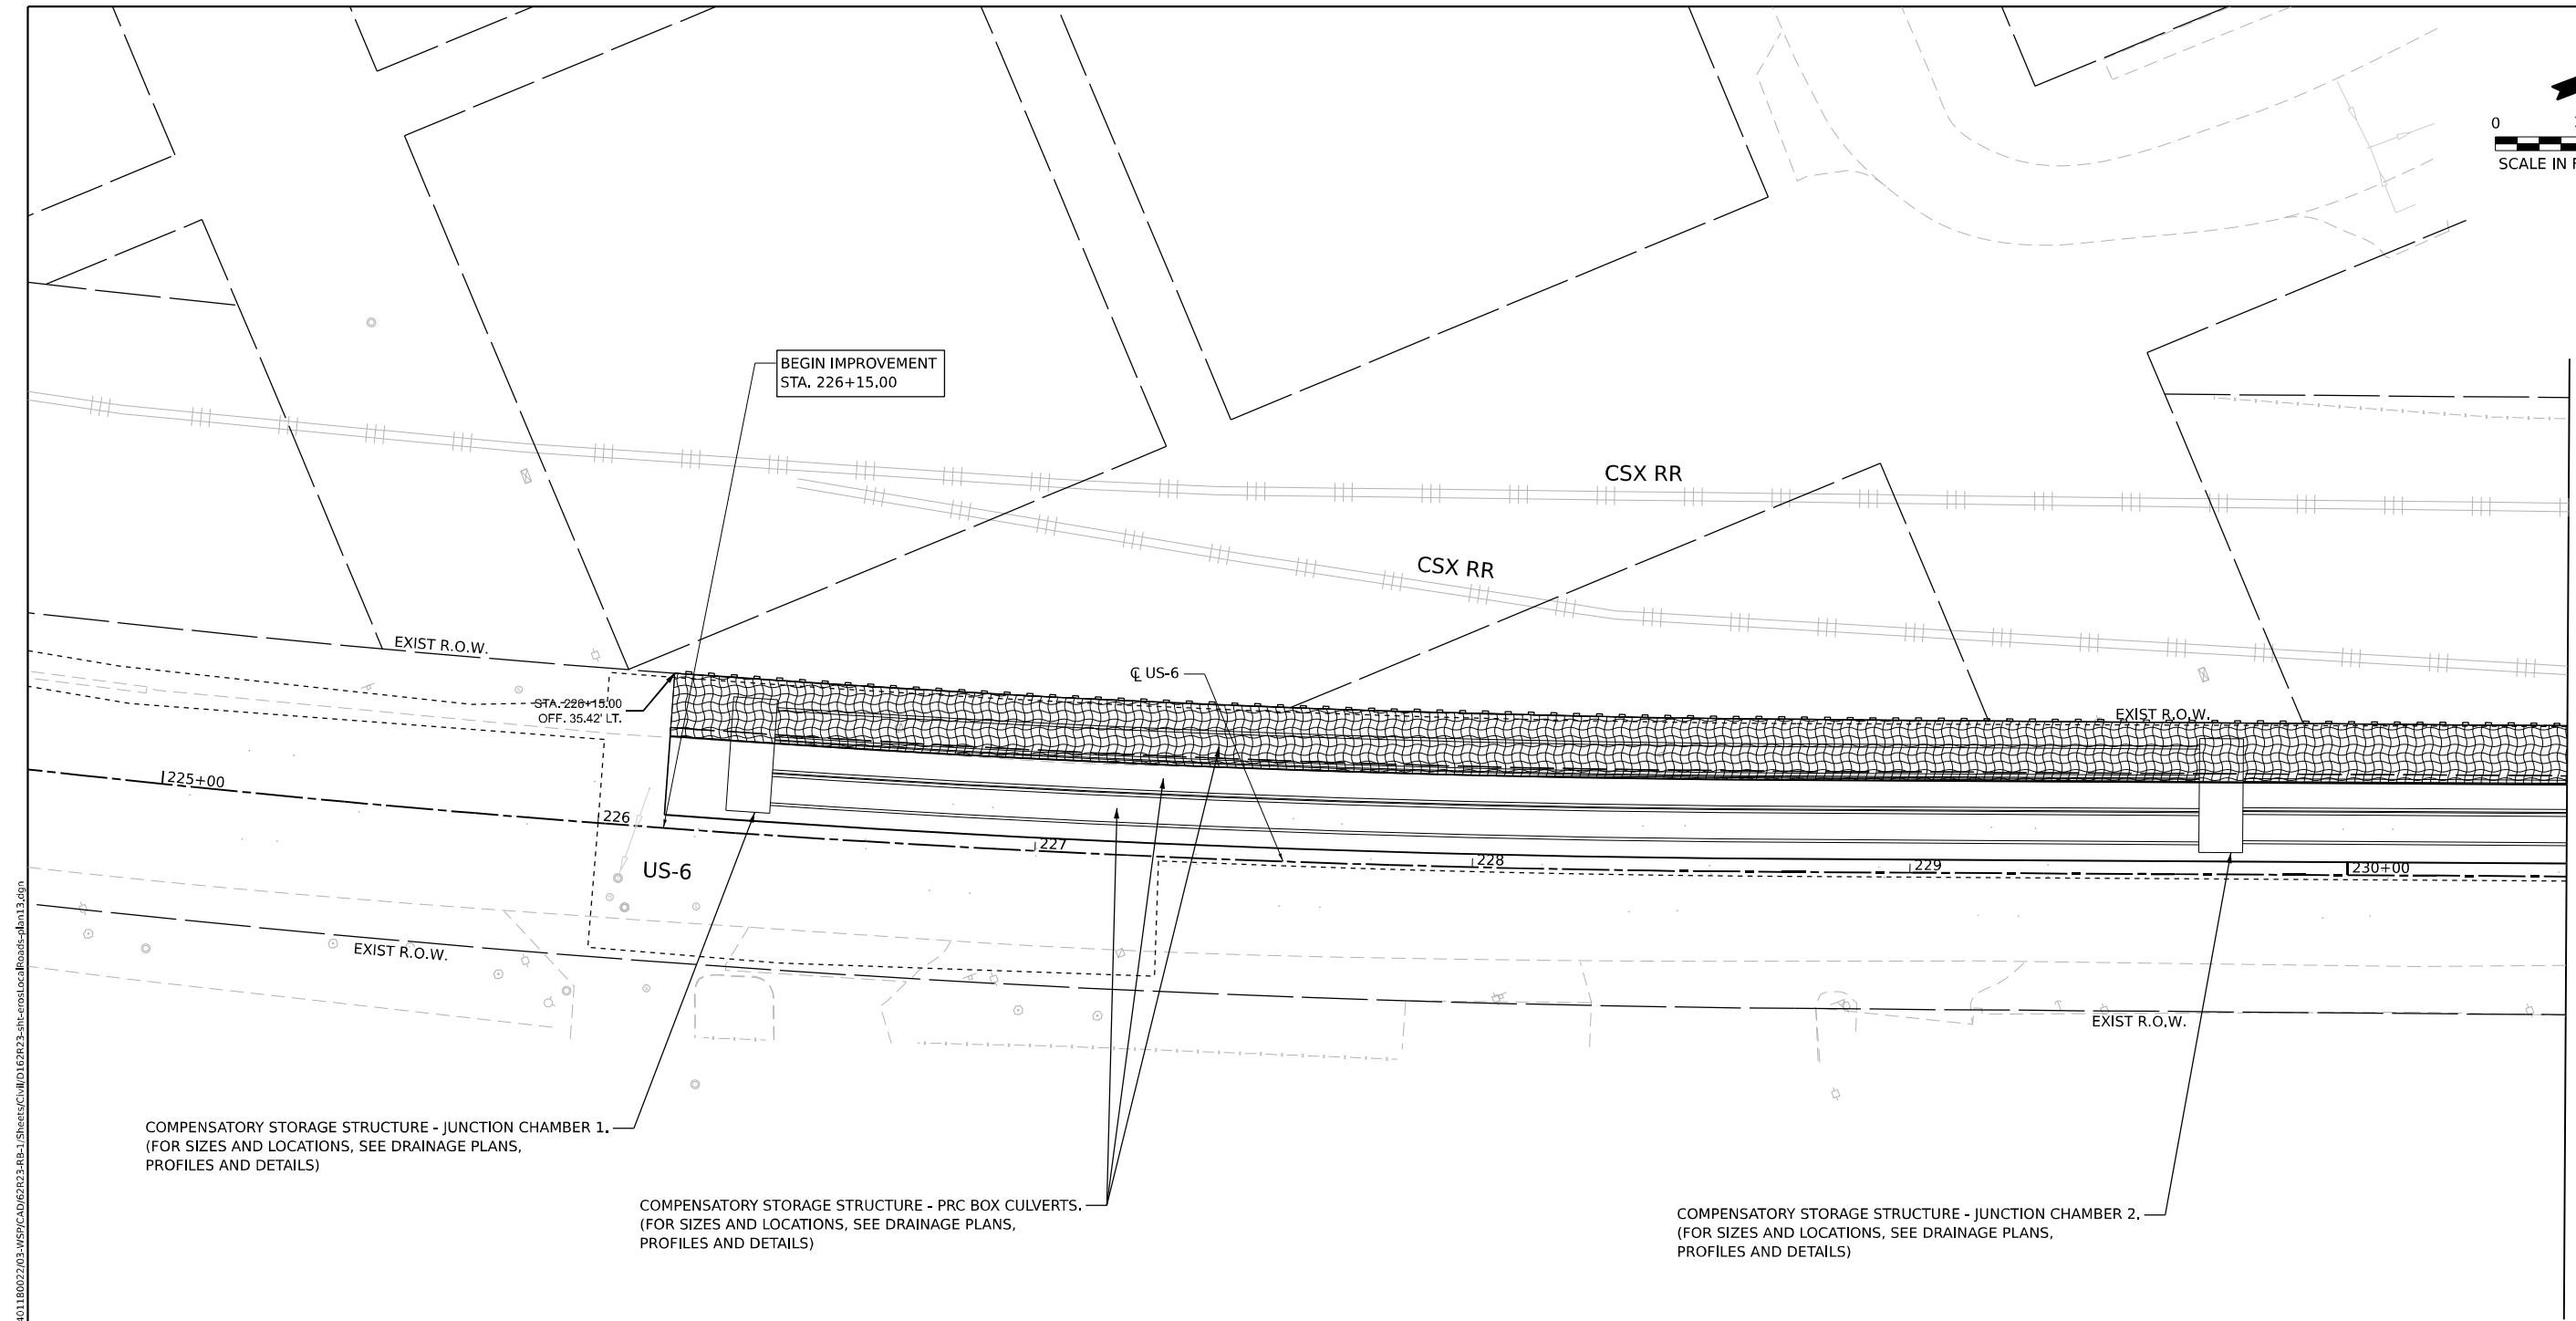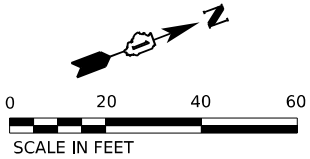

MATCHLINE STA. 230+50.00


COMPENSATORY STORAGE STRUCTURE - JUNCTION CHAMBER 1.
(FOR SIZES AND LOCATIONS, SEE DRAINAGE PLANS,
PROFILES AND DETAILS)

COMPENSATORY STORAGE STRUCTURE - PRC BOX CULVERTS.
(FOR SIZES AND LOCATIONS, SEE DRAINAGE PLANS,
PROFILES AND DETAILS)

COMPENSATORY STORAGE STRUCTURE - JUNCTION CHAMBER 2.
(FOR SIZES AND LOCATIONS, SEE DRAINAGE PLANS,
PROFILES AND DETAILS)

EROSION CONTROL LEGEND

- | | | | | | |
|--|--|--|---|--|--|
| | INLET FILTER | | TEMPORARY EROSION CONTROL SEEDING
MULCH, METHOD 2 | | TEMPORARY SEDIMENT BASIN |
| | TEMPORARY DITCH CHECK | | TEMPORARY EROSION CONTROL SEEDING
EROSION CONTROL BLANKET | | INLET PROTECTION
(UTILIZING TEMP DITCH CHECKS) |
| | PERIMETER EROSION BARRIER | | TEMPORARY EROSION CONTROL SEEDING
HEAVY DUTY EROSION CONTROL BLANKET | | AGGREGATE (EROSION CONTROL)
FILTER FABRIC |
| | RIPRAP
(SEE DRAINAGE PLANS FOR DETAILS) | | | | PAVEMENT CONSTRUCTED IN CURRENT
STAGE OR PREVIOUS STAGE |
| | | | | | TEMPORARY PAVEMENT |

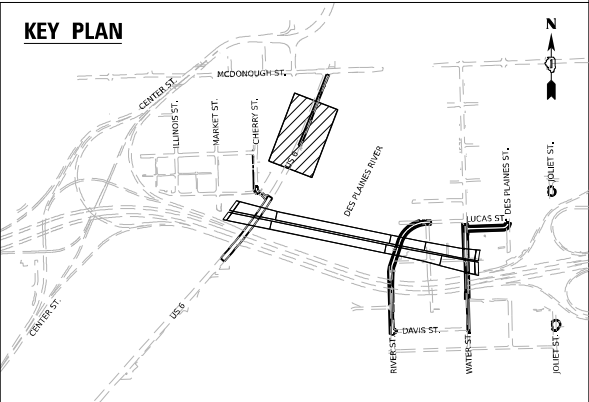

WSP USA Inc.
30 N. LA SALLE STREET
SUITE 4200
CHICAGO, IL 60602
TEL: (312) 782-8150

USER NAME	= USHC706648	DESIGNED	- CC	REVISED	-
		DRAWN	- XL	REVISED	-
PLOT SCALE	= 40,000' / in.	CHECKED	- DB	REVISED	-
PLOT DATE	= 11/6/2025	DATE	- 11/7/2025	REVISED	-



STATE OF ILLINOIS
DEPARTMENT OF TRANSPORTATION

EROSION CONTROL PLAN US-6

SCALE: 1"=20' SHEET 3 OF 12 SHEETS STA. TO STA.


F.A.I. RTE.	SECTION	COUNTY	TOTAL SHEETS	SHEET NO.
80	FAI 80 21 STRUCTURE 2	WILL	1230	311
CONTRACT NO. 62R23				
ILLINOIS FED. AID PROJECT				

MODEL: Default: p:\projects\trans\trans\p1\hatched\Documents\Projects_2018\CH401\401180022\03-MS9\CD\62R23-RB-1_Sheets\CD\62R23-shr-erosl.ocd\Roads\plan13-2.dgn

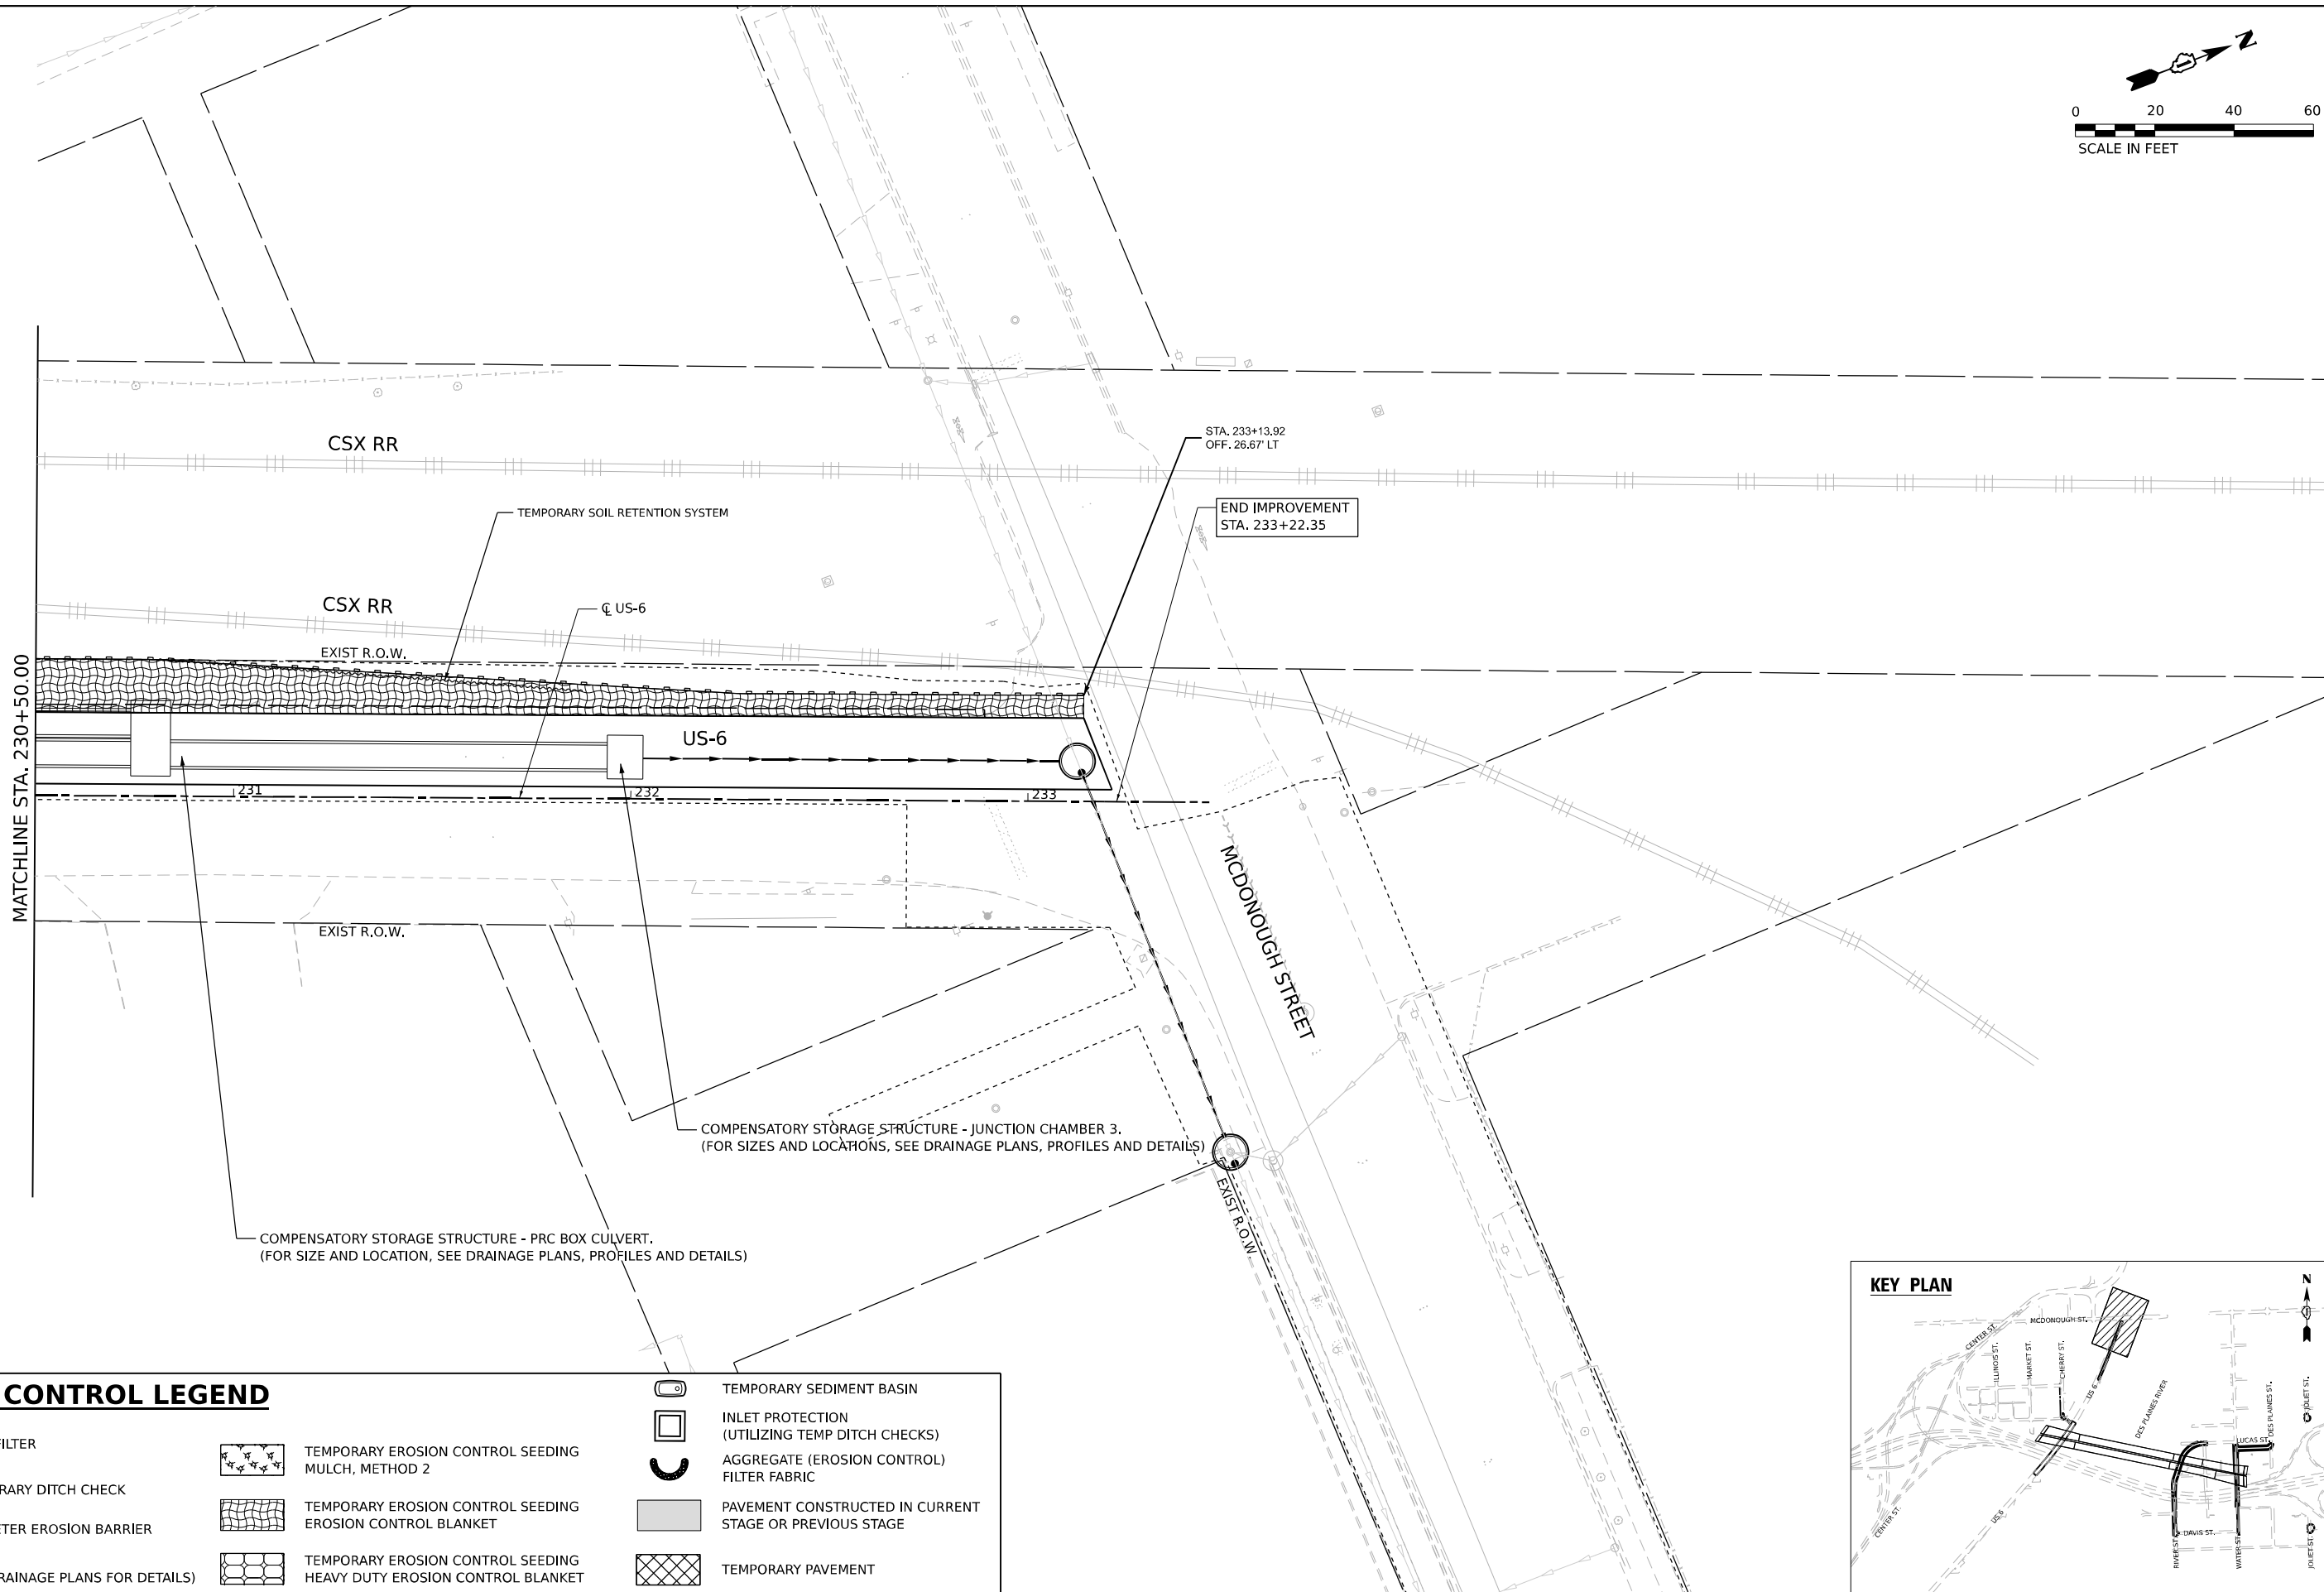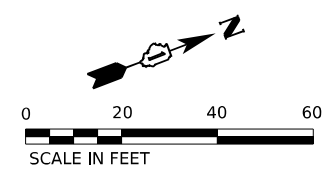

EROSION CONTROL LEGEND

- | | | | | | |
|--|---|--|--|--|---|
| | INLET FILTER | | TEMPORARY EROSION CONTROL SEEDING MULCH, METHOD 2 | | TEMPORARY SEDIMENT BASIN |
| | TEMPORARY DITCH CHECK | | TEMPORARY EROSION CONTROL SEEDING EROSION CONTROL BLANKET | | INLET PROTECTION (UTILIZING TEMP DITCH CHECKS) |
| | PERIMETER EROSION BARRIER | | TEMPORARY EROSION CONTROL SEEDING HEAVY DUTY EROSION CONTROL BLANKET | | AGGREGATE (EROSION CONTROL) FILTER FABRIC |
| | RIPRAP (SEE DRAINAGE PLANS FOR DETAILS) | | | | PAVEMENT CONSTRUCTED IN CURRENT STAGE OR PREVIOUS STAGE |
| | | | | | TEMPORARY PAVEMENT |

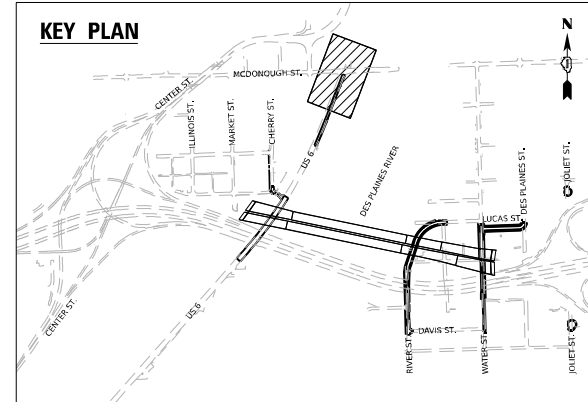

	WSP USA Inc. 30 N. LASALLE STREET SUITE 4200 CHICAGO, IL 60602 TEL: (312) 782-8150	USER NAME = USHC706648		DESIGNED - CC	REVISED -	STATE OF ILLINOIS DEPARTMENT OF TRANSPORTATION	EROSION CONTROL PLAN US-6			F.A.I. RTE.	SECTION	COUNTY	TOTAL SHEETS	SHEET NO.
		DRAWN - XL		REVISIED -	REVISIED -					80	FAI 80 21 STRUCTURE 2	WILL	1230	312
		PLOT SCALE = 40,000' / in.		CHECKED - DB	REVISIED -					CONTRACT NO. 62R23				
		PLOT DATE = 11/6/2025		DATE - 11/7/2025	REVISIED -		SCALE: 1"=20'		SHEET 4 OF 12 SHEETS	STA.	TO STA.	ILLINOIS FED. AID PROJECT		

EROSION CONTROL LEGEND

- 
INLET FILTER


TEMPORARY DITCH CHECK


PERIMETER EROSION BARRIER


RIPRAP
(SEE DRAINAGE PLANS FOR DETAILS)
- 
TEMPORARY EROSION CONTROL SEEDING
MULCH, METHOD 2


TEMPORARY EROSION CONTROL SEEDING
EROSION CONTROL BLANKET



 

TEMPORARY EROSION CONTROL SEEDING
HEAVY DUTY EROSION CONTROL BLANKET
- 
TEMPORARY SEDIMENT BASIN


INLET PROTECTION
(UTILIZING TEMP DITCH CHECKS)


AGGREGATE (EROSION CONTROL)
FILTER FABRIC


PAVEMENT CONSTRUCTED IN CURRENT
STAGE OR PREVIOUS STAGE


TEMPORARY PAVEMENT

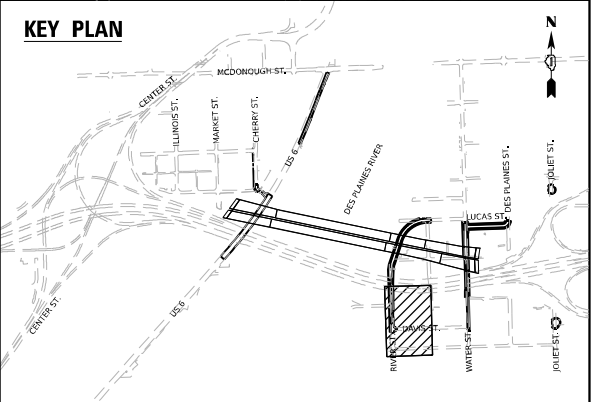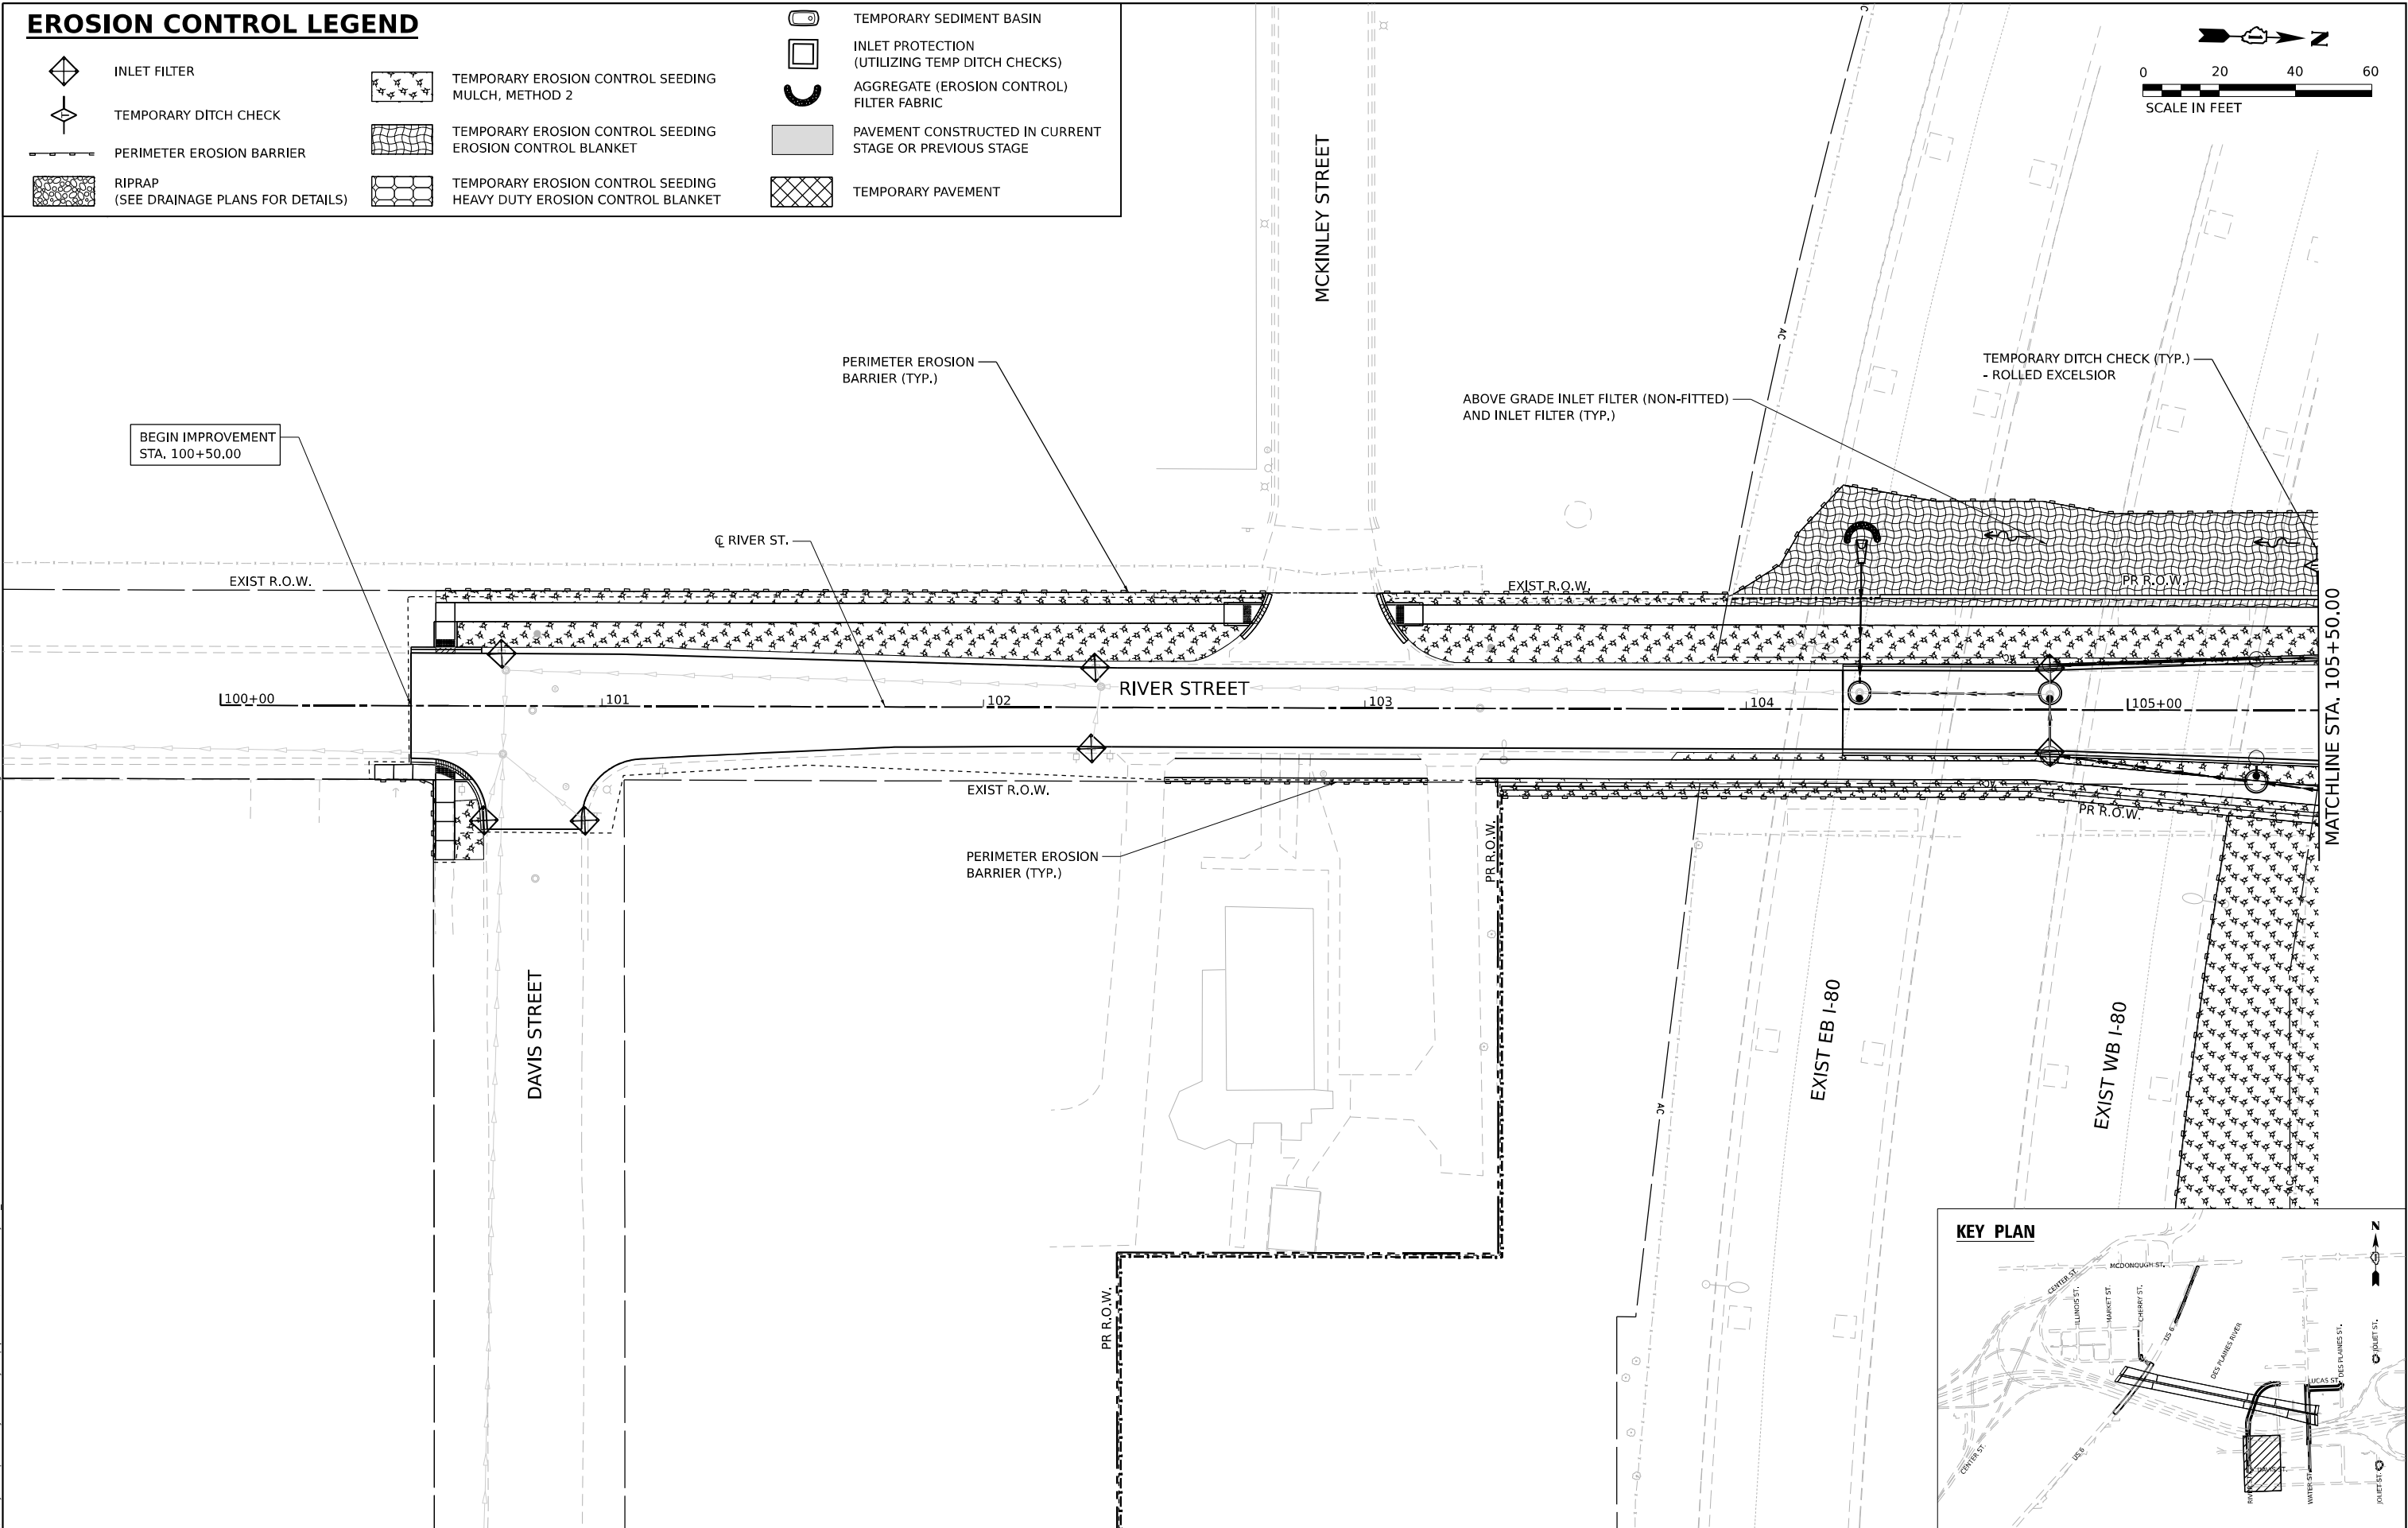

 WSP USA Inc. 30 N. LA SALLE STREET SUITE 4200 CHICAGO, IL 60602 TEL: (312) 782-8150	USER NAME = USHC706648	DESIGNED - CC	REVISED -	STATE OF ILLINOIS DEPARTMENT OF TRANSPORTATION	EROSION CONTROL PLAN RIVER STREET				F.A.I. RTE.	SECTION	COUNTY	TOTAL SHEETS	SHEET NO.
	PLOT SCALE = 40,000' / in.	CHECKED - DL	REVISED -						80	FAI 80 21 STRUCTURE 2	WILL	1230	313
	PLOT DATE = 11/6/2025	DATE - 11/7/2025	REVISED -		SCALE: 1"=20'		SHEET 5 OF 12 SHEETS	STA.	TO STA.	CONTRACT NO. 62R23			
										ILLINOIS FED. AID PROJECT			

EROSION CONTROL LEGEND

- 

INLET FILTER
- 

TEMPORARY DITCH CHECK
- 

PERIMETER EROSION BARRIER
- 

RIPRAP
(SEE DRAINAGE PLANS FOR DETAILS)
- 

TEMPORARY EROSION CONTROL SEEDING
MULCH, METHOD 2
- 

TEMPORARY EROSION CONTROL SEEDING
EROSION CONTROL BLANKET
- 

TEMPORARY EROSION CONTROL SEEDING
HEAVY DUTY EROSION CONTROL BLANKET
- 

TEMPORARY SEDIMENT BASIN
- 

INLET PROTECTION
(UTILIZING TEMP DITCH CHECKS)
- 


AGGREGATE (EROSION CONTROL)
FILTER FABRIC
- 

PAVEMENT CONSTRUCTED IN CURRENT
STAGE OR PREVIOUS STAGE
- 



TEMPORARY PAVEMENT

TEMPORARY DITCH CHECK (TYP.)
- ROLLED EXCELSIOR

PERIMETER EROSION
BARRIER (TYP.)

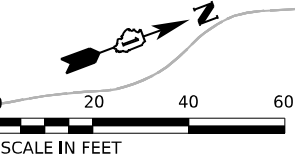




APPROX ZONE AE 100-YR FLOODPLAIN BOUNDARY
(JOLIET FLOW MAIN DRAIN), BFE=524.5'

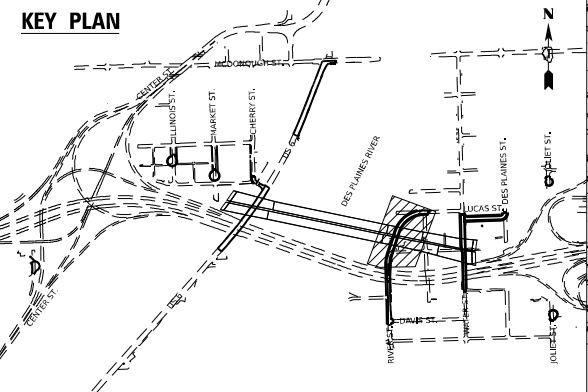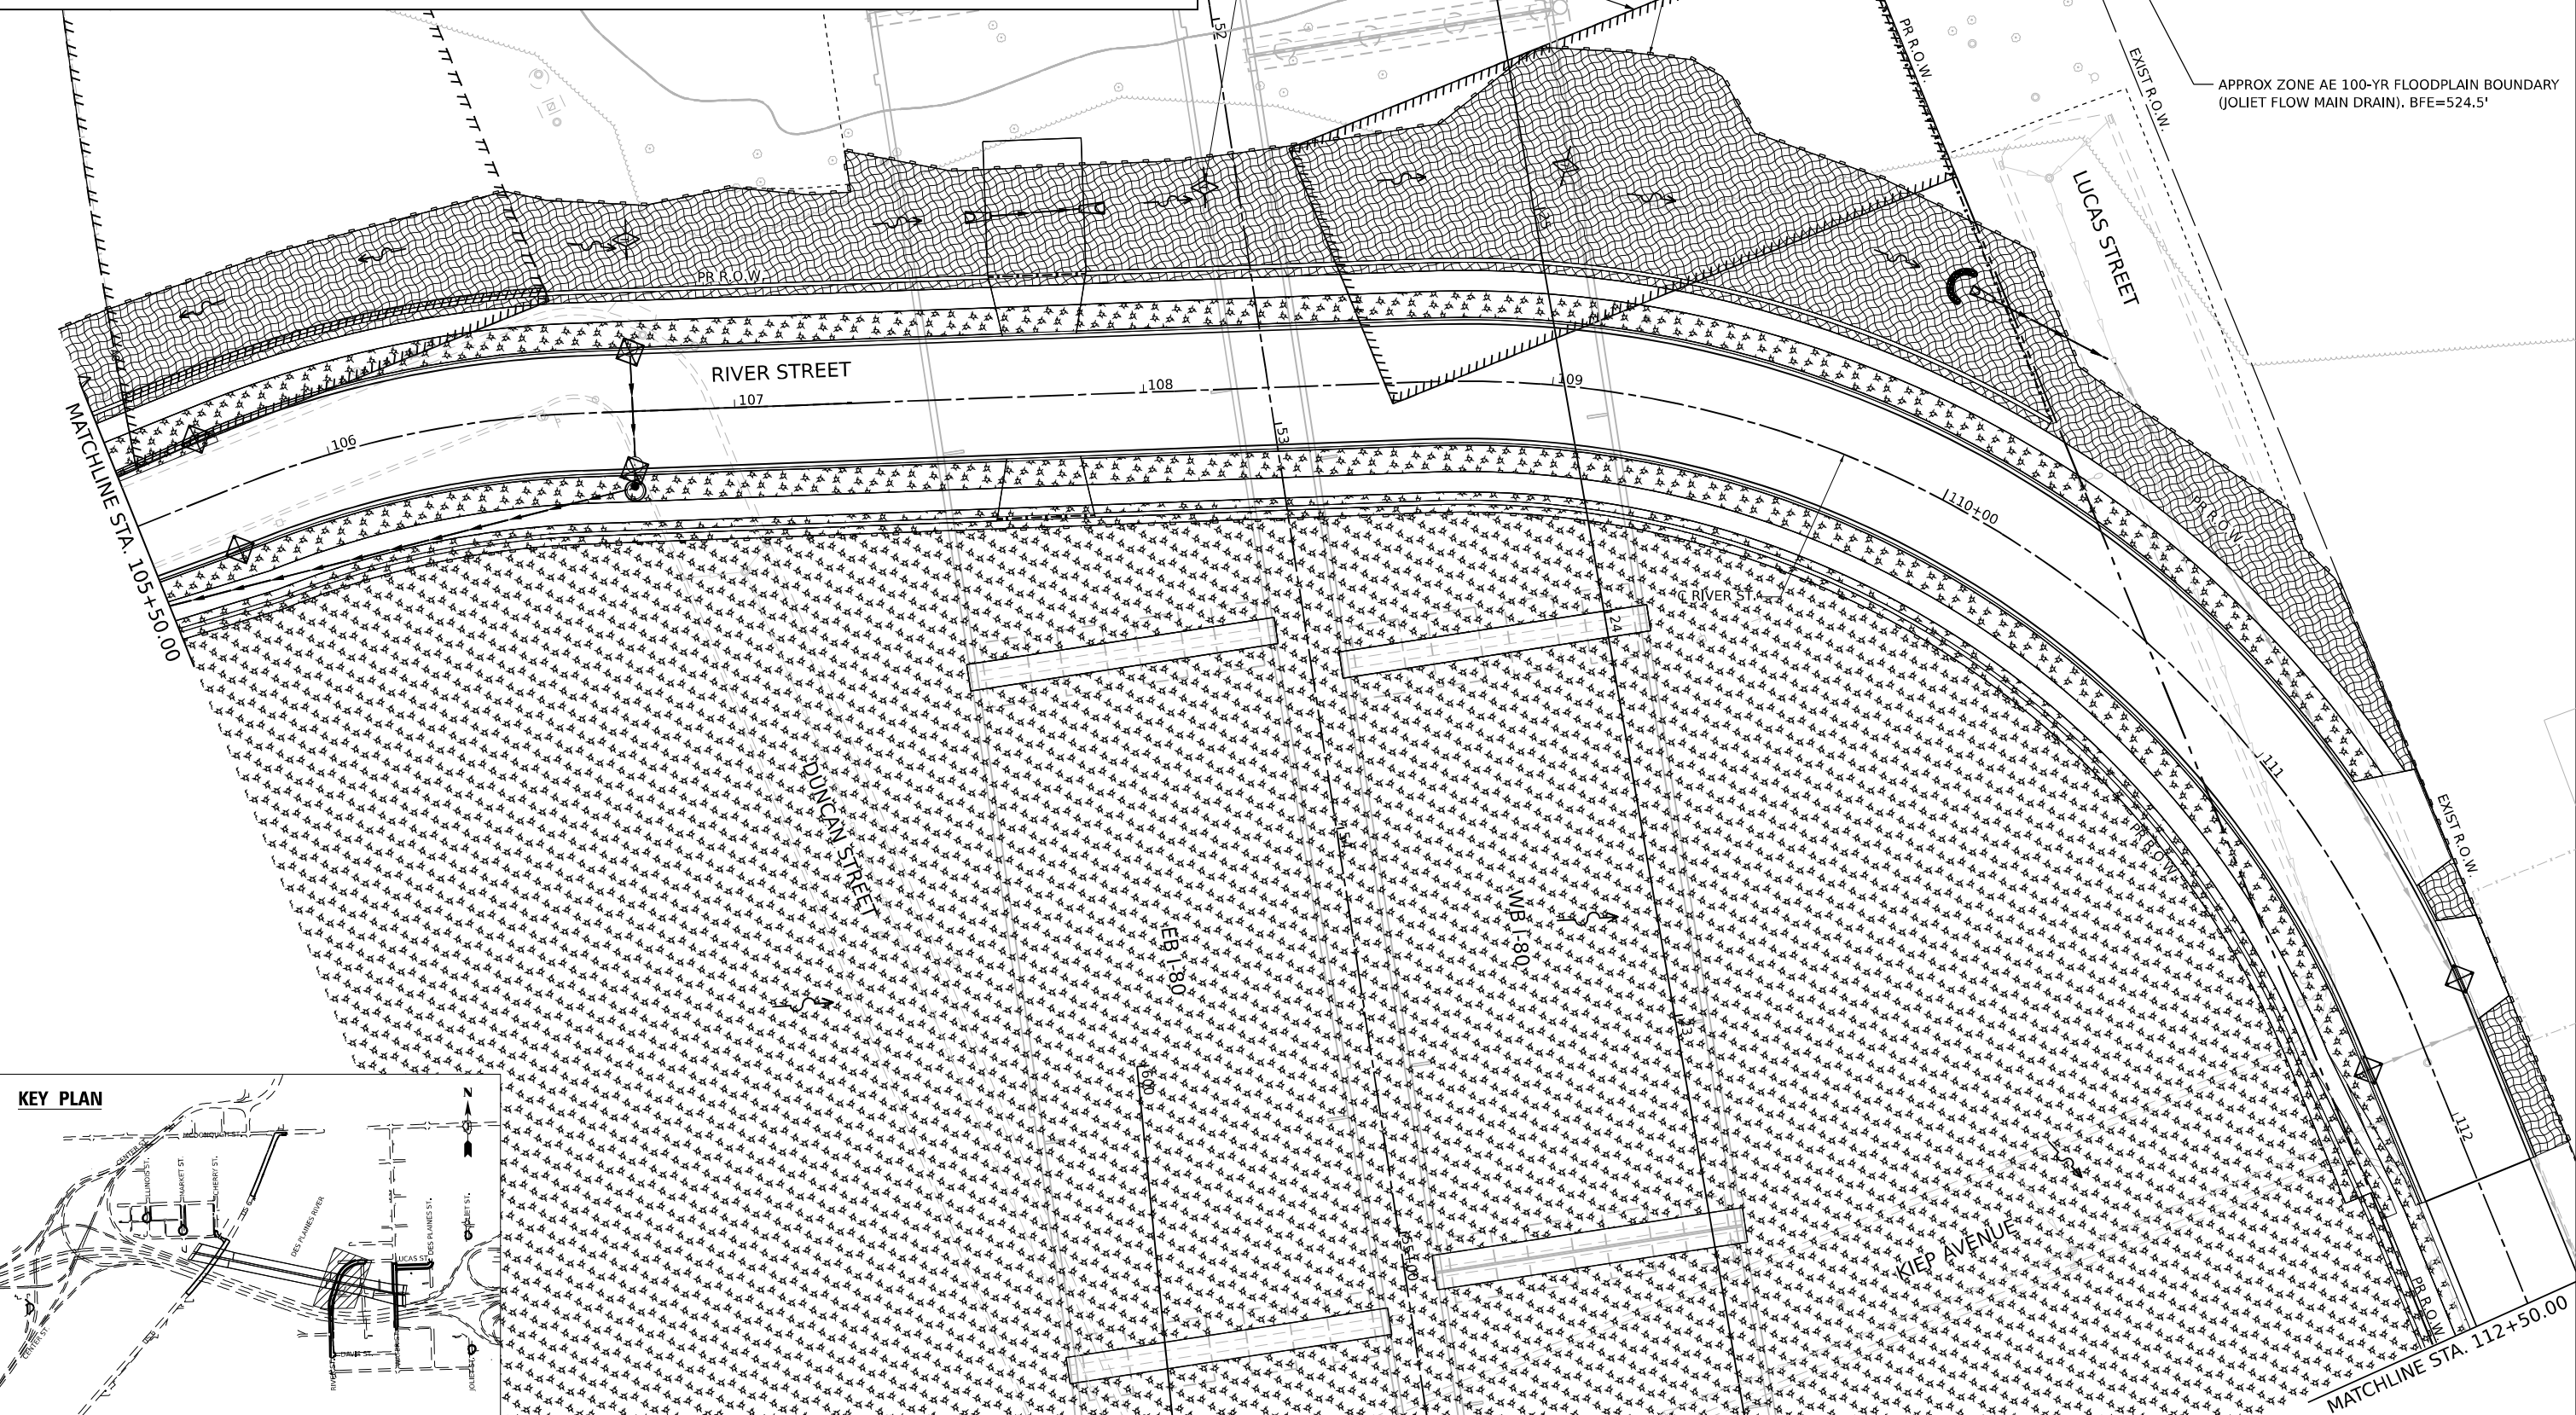


 WSP USA INC. 30 N. LASALLE STREET SUITE 4200 CHICAGO, IL 60602 TEL: (312) 782-8150	USER NAME = USHC706648	DESIGNED - CC	REVISED -	STATE OF ILLINOIS DEPARTMENT OF TRANSPORTATION	EROSION CONTROL PLAN RIVER STREET				F.A.I. RTE.	SECTION	COUNTY	TOTAL SHEETS	SHEET NO.
	PLOT SCALE = 40,000' / in.	CHECKED - DB	REVISED -		80	FAI 80 21 STRUCTURE 2	WILL	1230	314				
	PLOT DATE = 11/6/2025	DATE - 11/7/2025	REVISED -		CONTRACT NO. 62R23								
	SCALE: 1"=20'				SHEET 6	OF 12 SHEETS	STA.	TO STA.					
								ILLINOIS FED. AID PROJECT					

	INLET FILTER		TEMPORARY EROSION CONTROL SEEDING MULCH, METHOD 2
	TEMPORARY DITCH CHECK		TEMPORARY EROSION CONTROL SEEDING EROSION CONTROL BLANKET
	PERIMETER EROSION BARRIER		TEMPORARY EROSION CONTROL SEEDING HEAVY DUTY EROSION CONTROL BLANKET
	RIPRAP (SEE DRAINAGE PLANS FOR DETAILS)		

	TEMPORARY SEDIMENT BASIN
	INLET PROTECTION (UTILIZING TEMP DITCH CHECKS)
	AGGREGATE (EROSION CONTROL) FILTER FABRIC
	PAVEMENT CONSTRUCTED IN CURRENT STAGE OR PREVIOUS STAGE
	TEMPORARY PAVEMENT

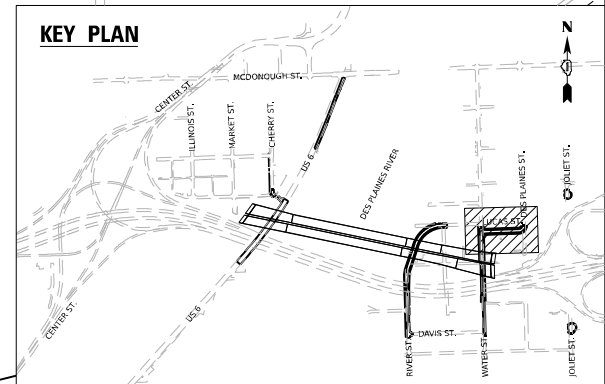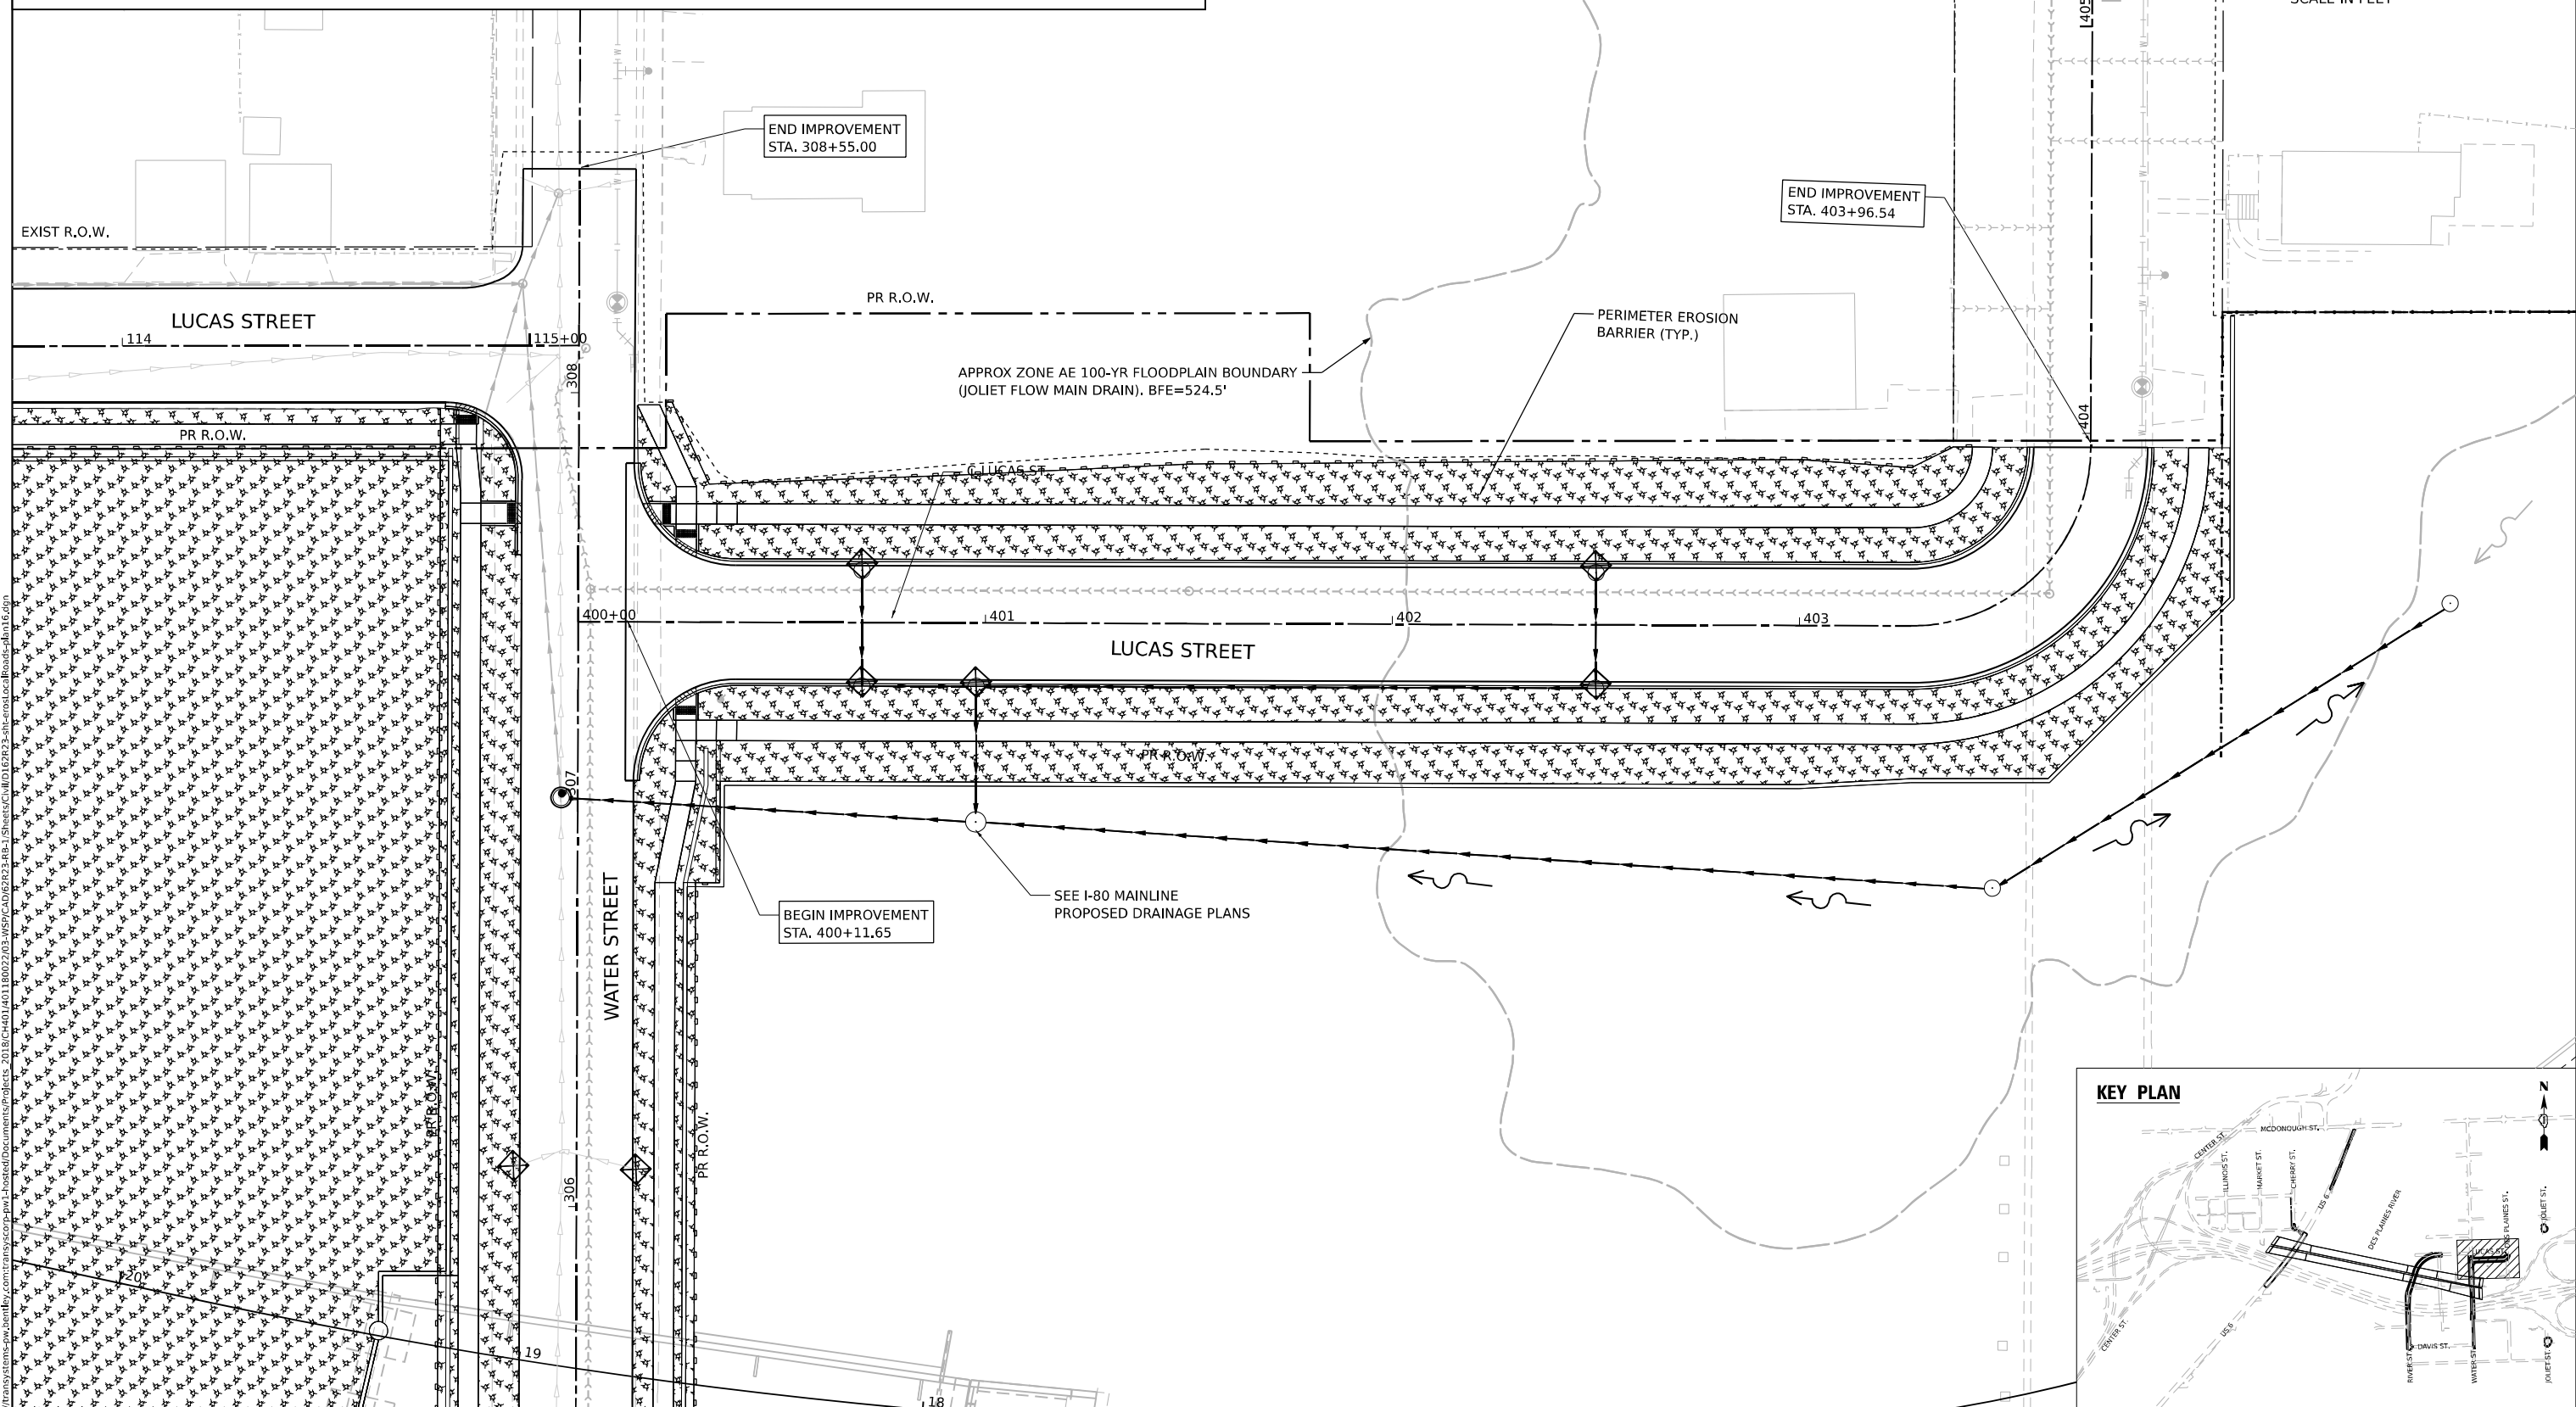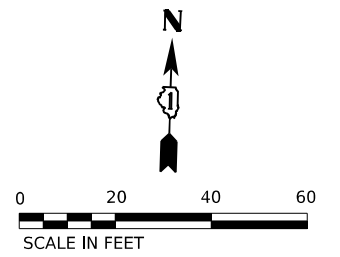


Model: Default
File Name: p:\projects\transstone-pw-bentley.com\transstone-pw-labeled\Documents\Projects_2018\CH4001401180022\03-W59\CAD\62R23-RB-1_Sheets\CH4001401180022-shr-erost-oc\Roads-plan1.dgn

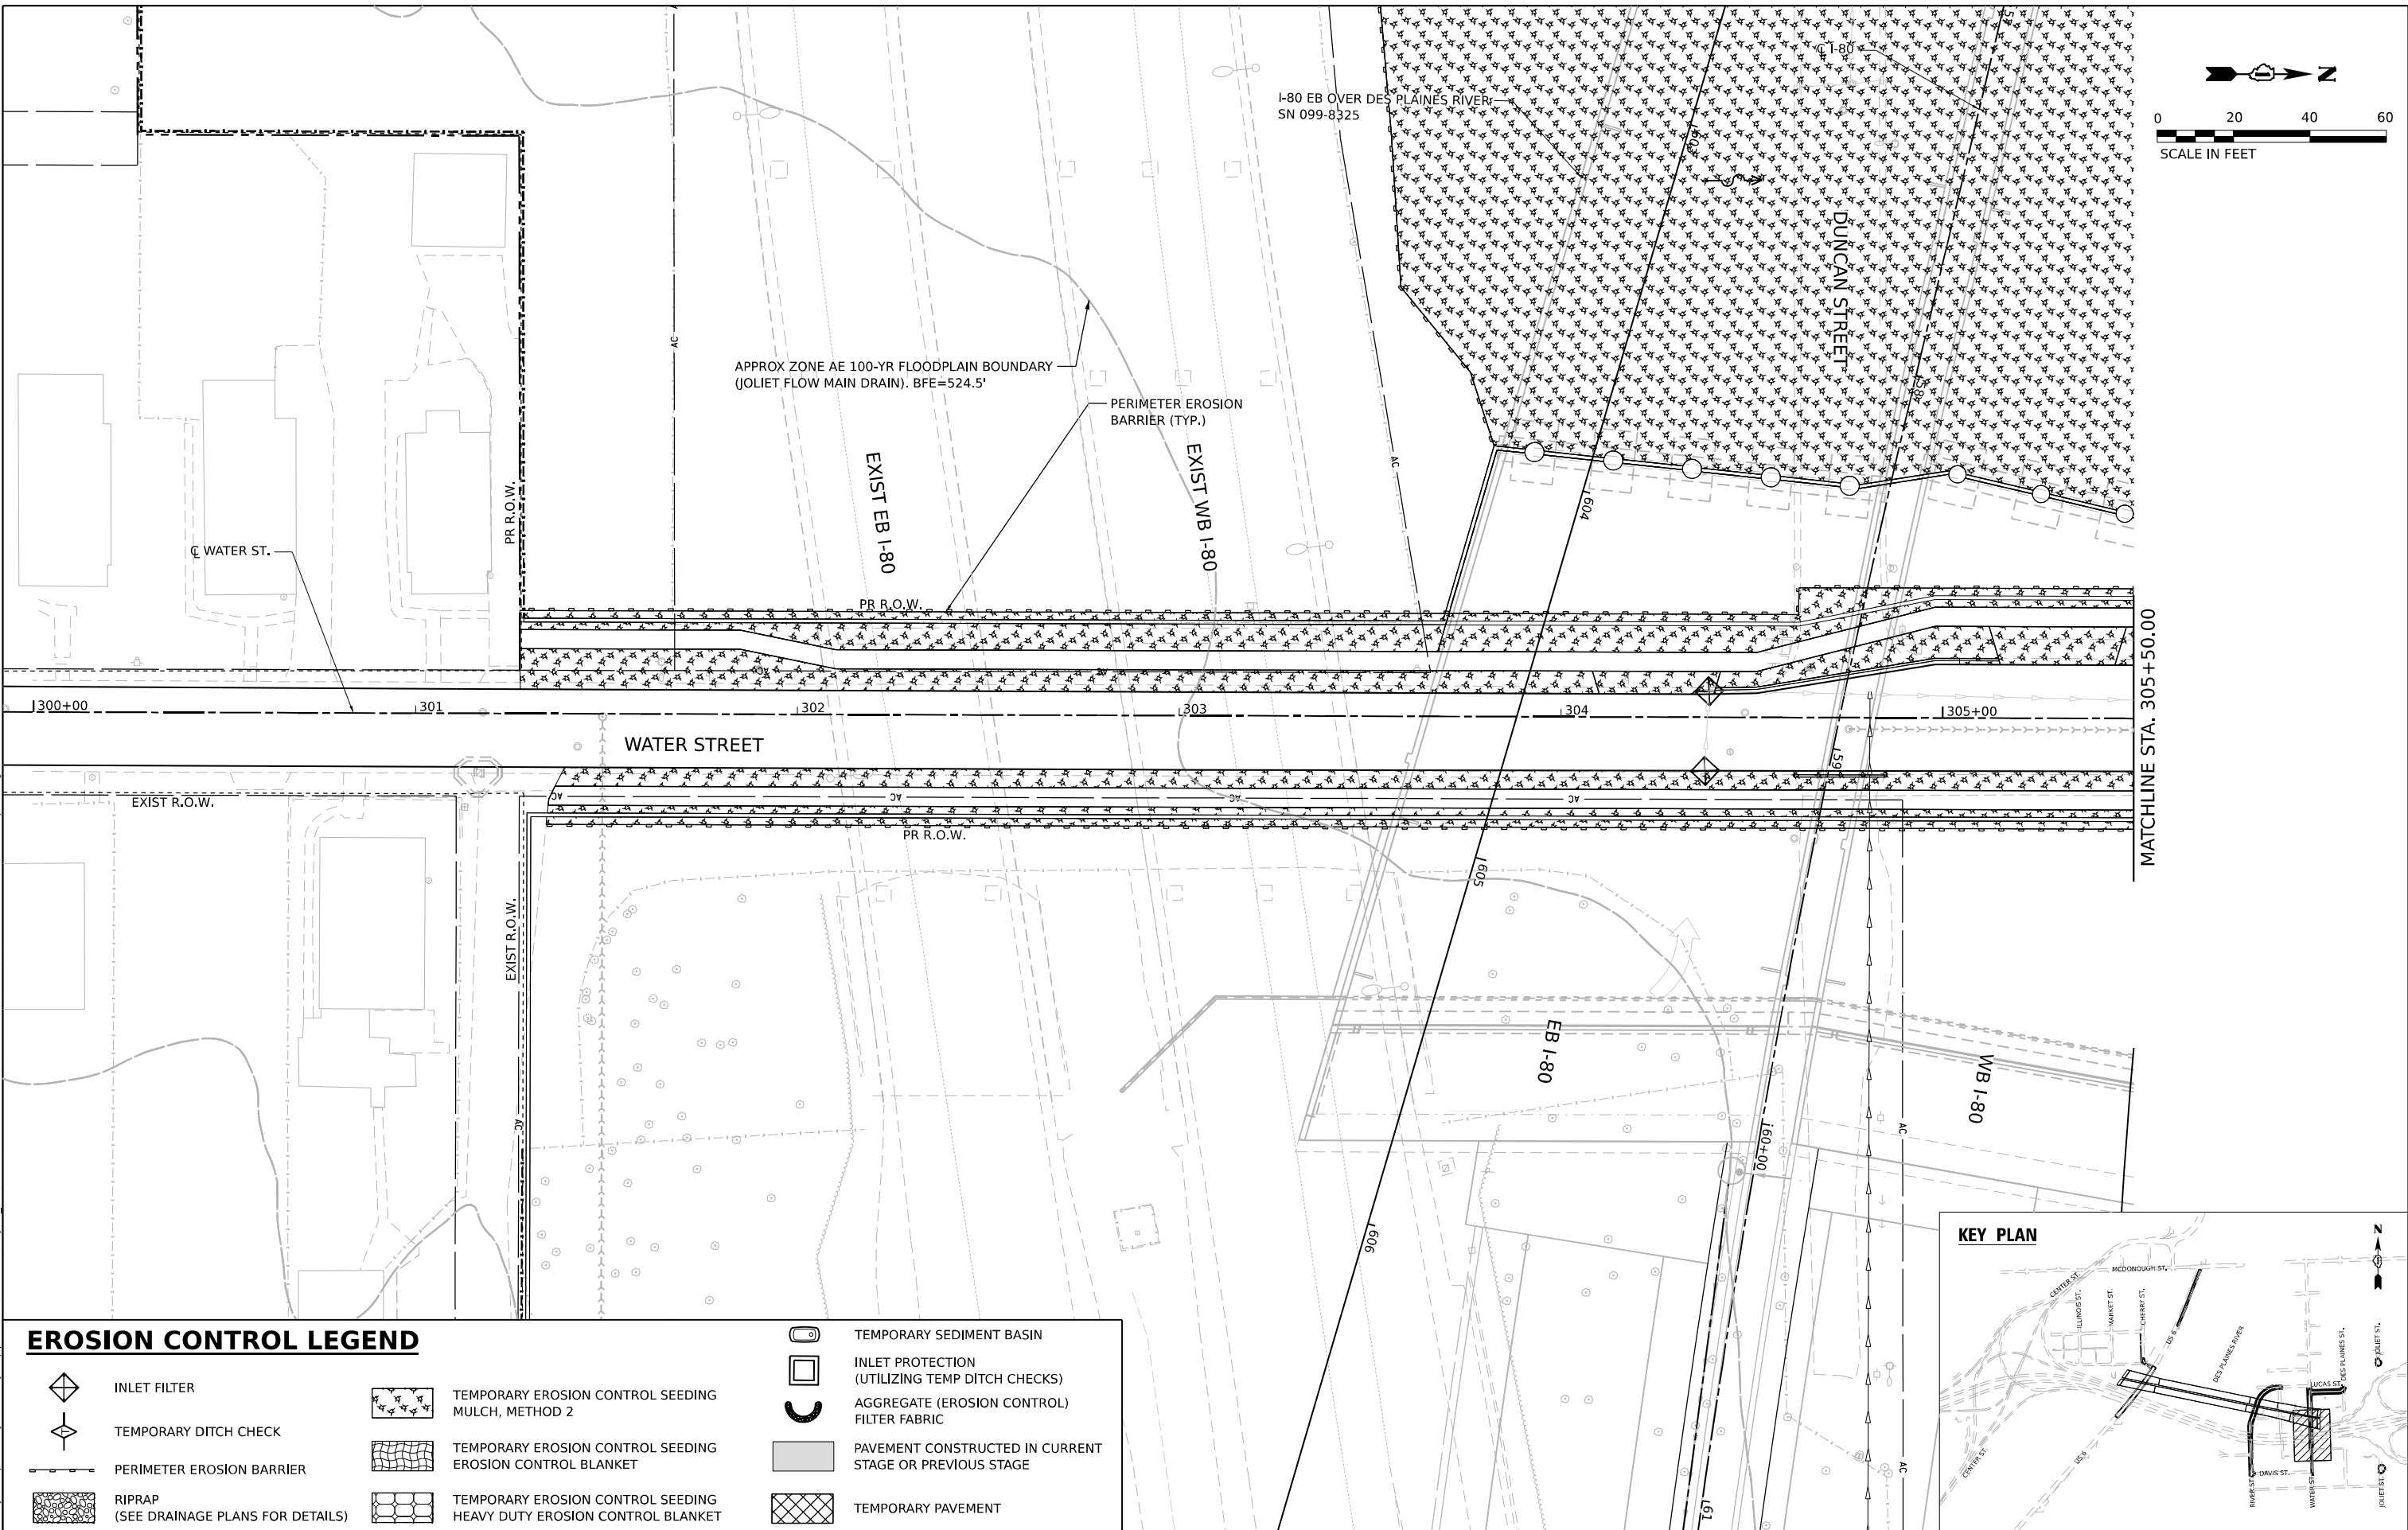

EROSION CONTROL LEGEND

- | | | | | | |
|--|---|--|--|--|---|
| | INLET FILTER | | TEMPORARY EROSION CONTROL SEEDING MULCH, METHOD 2 | | INLET PROTECTION (UTILIZING TEMP DITCH CHECKS) |
| | TEMPORARY DITCH CHECK | | TEMPORARY EROSION CONTROL SEEDING EROSION CONTROL BLANKET | | AGGREGATE (EROSION CONTROL) FILTER FABRIC |
| | PERIMETER EROSION BARRIER | | TEMPORARY EROSION CONTROL SEEDING HEAVY DUTY EROSION CONTROL BLANKET | | PAVEMENT CONSTRUCTED IN CURRENT STAGE OR PREVIOUS STAGE |
| | RIPRAP (SEE DRAINAGE PLANS FOR DETAILS) | | TEMPORARY PAVEMENT | | |

KEY PLAN

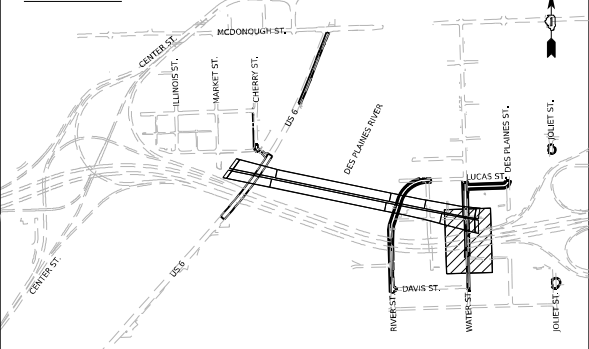

 WSP USA Inc. 30 N. LASALLE STREET SUITE 4200 CHICAGO, IL 60602 TEL: (312) 782-8150	USER NAME = USHC706648		DESIGNED - CC	REVISED -	STATE OF ILLINOIS DEPARTMENT OF TRANSPORTATION				EROSION CONTROL PLAN					F.A.I. RTE.	SECTION	COUNTY	TOTAL SHEETS	SHEET NO.	
	DRAWN - XL		REVISIED -	REVISED -					WATER STREET					80	FAI 80 21 STRUCTURE 2	WILL	1230	316	
	PLOT SCALE = 40,000' / in.		CHECKED - DB	REVISED -					CONTRACT NO. 62R23										
	PLOT DATE = 11/6/2025		DATE - 11/7/2025	REVISED -					SCALE: 1"=20'					SHEET 8 OF 12 SHEETS	STA.	TO STA.			

EROSION CONTROL LEGEND

- 

INLET FILTER
- 

TEMPORARY DITCH CHECK
- 

PERIMETER EROSION BARRIER
- 

RIPRAP
(SEE DRAINAGE PLANS FOR DETAILS)
- 

TEMPORARY EROSION CONTROL SEEDING
MULCH, METHOD 2
- 

TEMPORARY EROSION CONTROL SEEDING
EROSION CONTROL BLANKET
- 

TEMPORARY EROSION CONTROL SEEDING
HEAVY DUTY EROSION CONTROL BLANKET
- 




TEMPORARY SEDIMENT BASIN
- 

INLET PROTECTION
(UTILIZING TEMP DITCH CHECKS)
- 

AGGREGATE (EROSION CONTROL)
FILTER FABRIC
- 

PAVEMENT CONSTRUCTED IN CURRENT
STAGE OR PREVIOUS STAGE
- 

TEMPORARY PAVEMENT

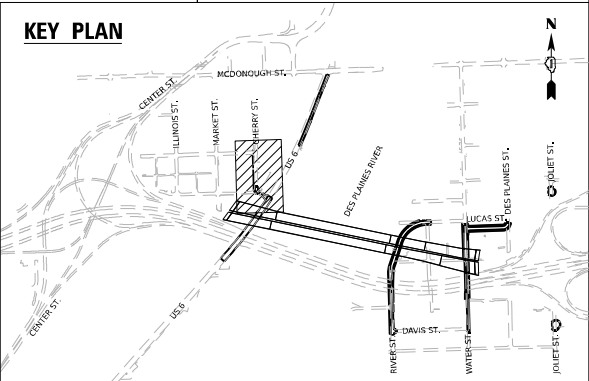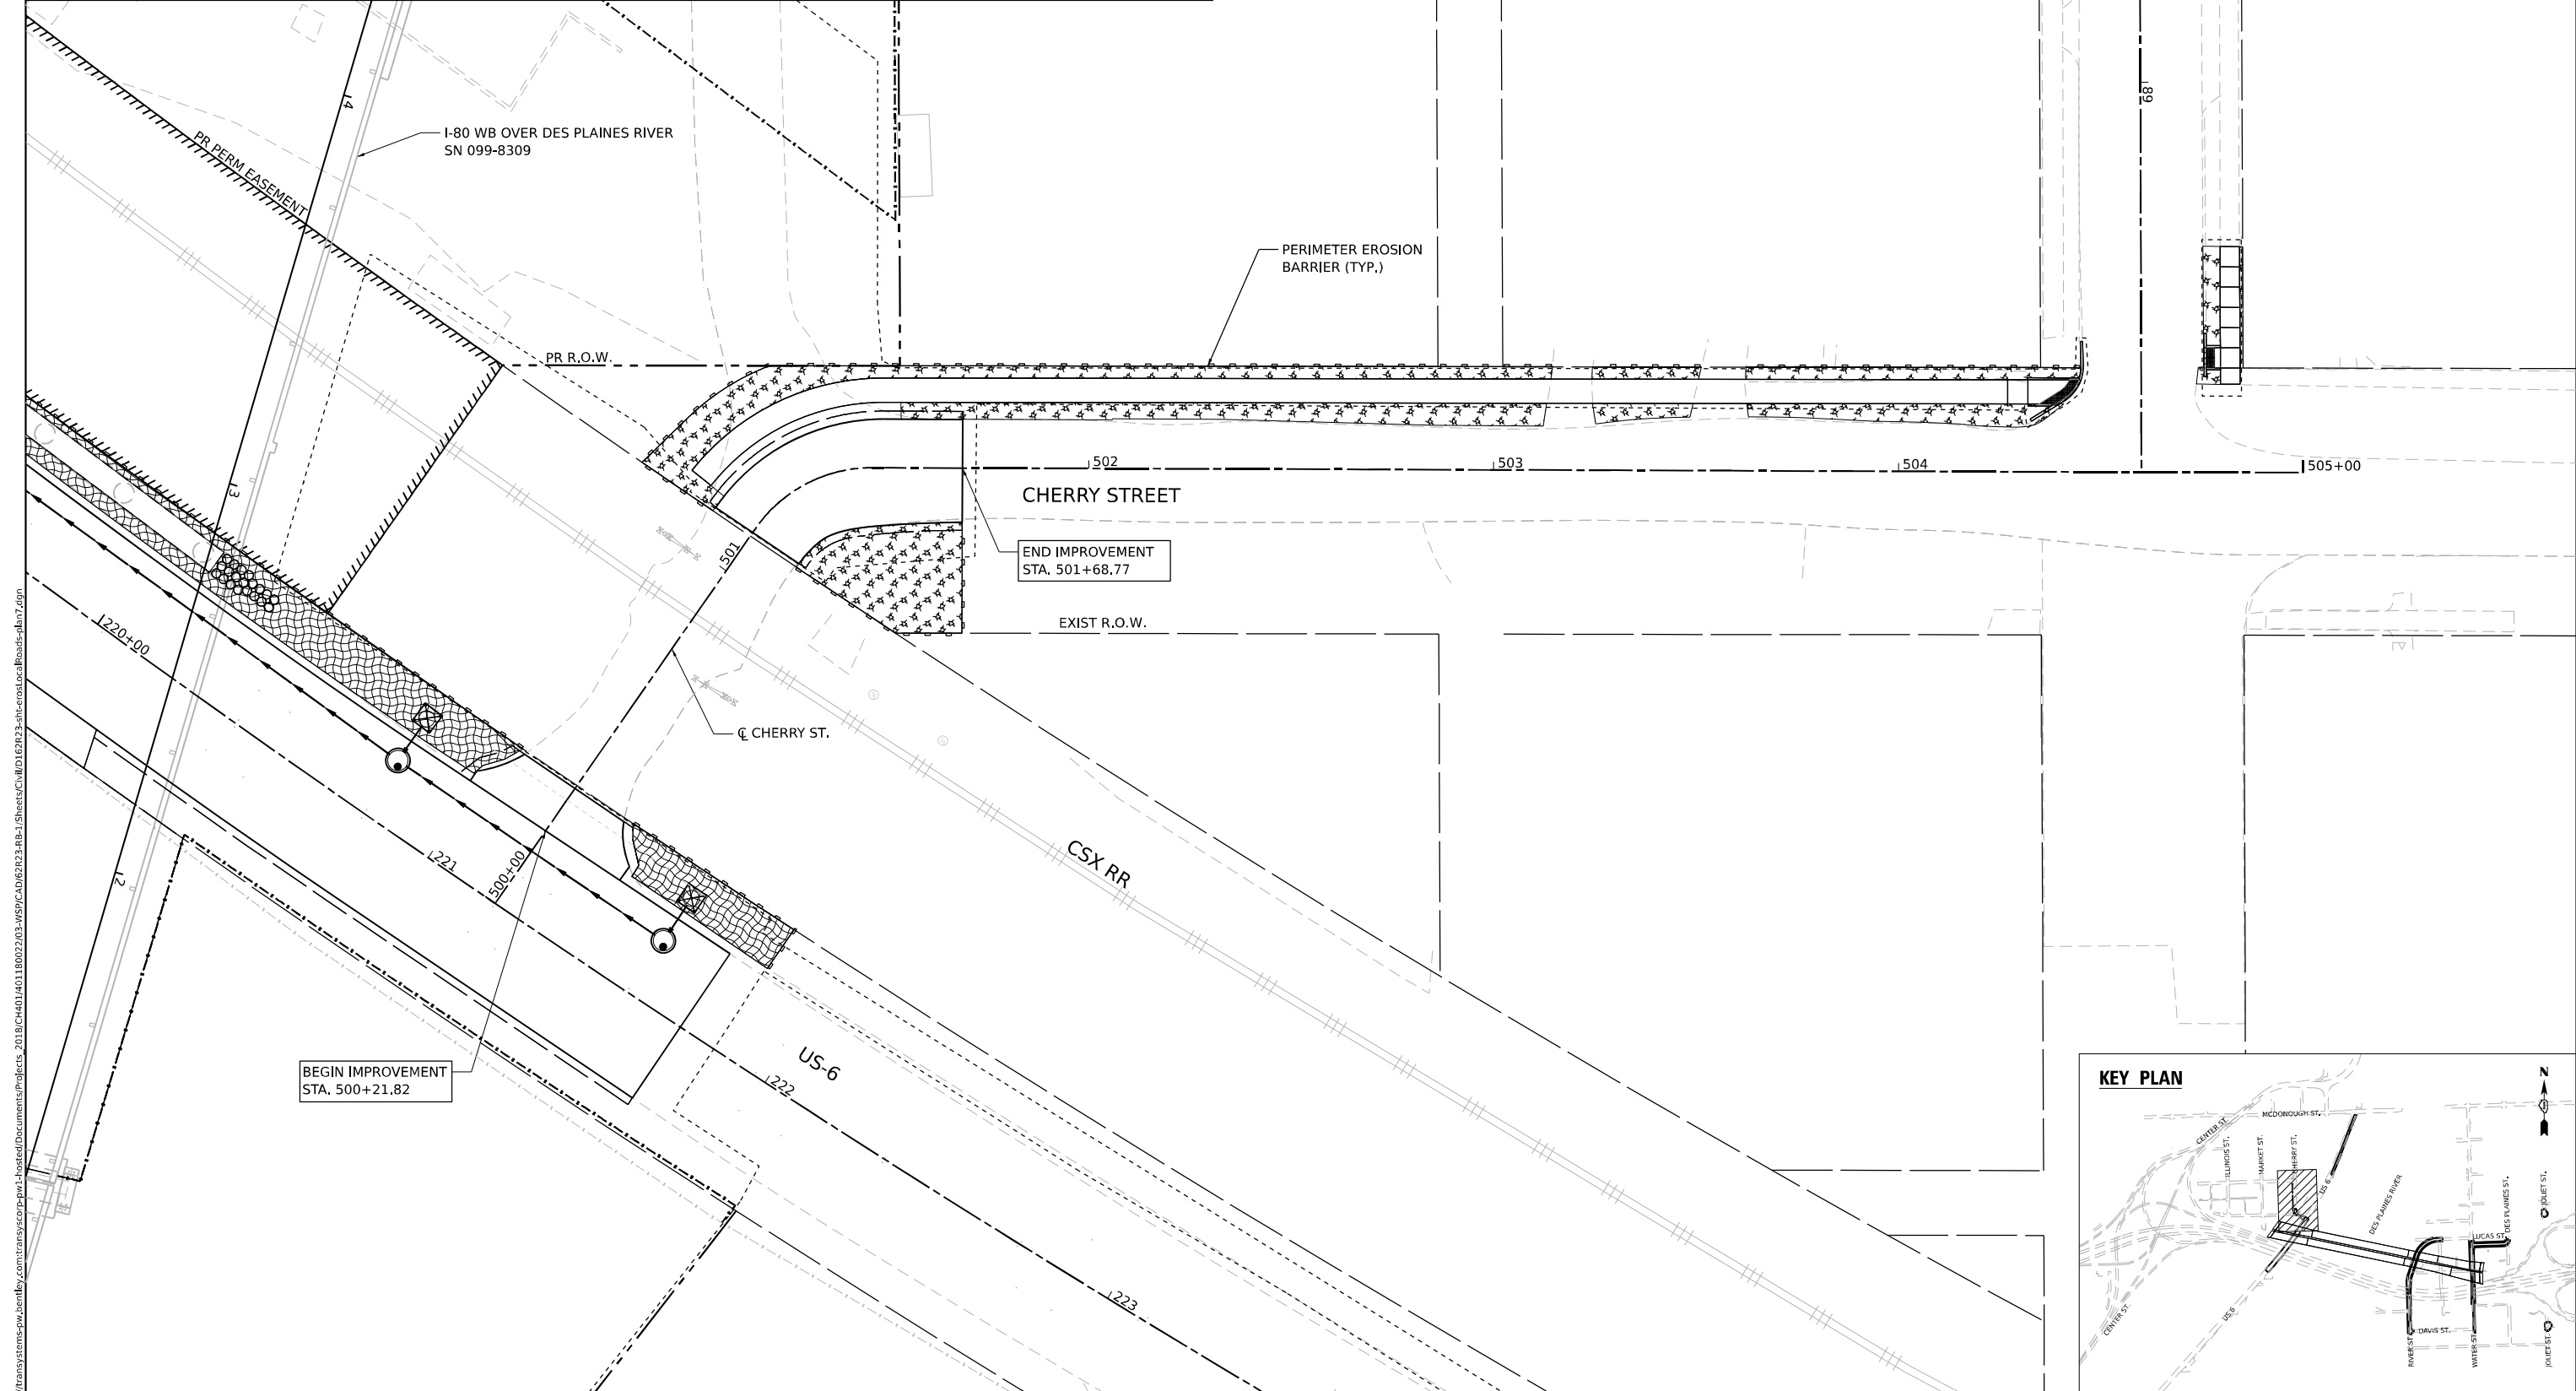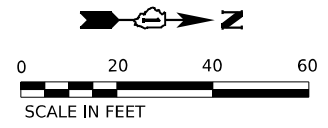

 WSP USA INC. 30 N. LASALLE STREET SUITE 4200 CHICAGO, IL 60602 TEL: (312) 782-8150	USER NAME = USHC706648		DESIGNED - CC	REVISED -	STATE OF ILLINOIS DEPARTMENT OF TRANSPORTATION	EROSION CONTROL PLAN CHERRY STREET	F.A.I. RTE. 80		SECTION FAI 80 21 STRUCTURE 2	COUNTY WILL	TOTAL SHEETS 1230	SHEET NO. 318
	PLOT SCALE = 40,000' / in.		CHECKED - DB	REVISED -					CONTRACT NO. 62R23			
	PLOT DATE = 11/6/2025		DATE - 11/7/2025	REVISED -					ILLINOIS FED. AID PROJECT			
							SCALE: 1"=20'		SHEET 10 OF 12 SHEETS	STA.	TO STA.	

EROSION CONTROL LEGEND

- 

INLET FILTER
- 

TEMPORARY DITCH CHECK
- 

PERIMETER EROSION BARRIER
- 

RIPRAP
(SEE DRAINAGE PLANS FOR DETAILS)
- 

TEMPORARY EROSION CONTROL SEEDING
MULCH, METHOD 2
- 

TEMPORARY EROSION CONTROL SEEDING
EROSION CONTROL BLANKET
- 

TEMPORARY EROSION CONTROL SEEDING
HEAVY DUTY EROSION CONTROL BLANKET

- 




TEMPORARY SEDIMENT BASIN
- 

INLET PROTECTION
(UTILIZING TEMP DITCH CHECKS)
- 

AGGREGATE (EROSION CONTROL)
FILTER FABRIC
- 


PAVEMENT CONSTRUCTED IN CURRENT
STAGE OR PREVIOUS STAGE
- 

TEMPORARY PAVEMENT

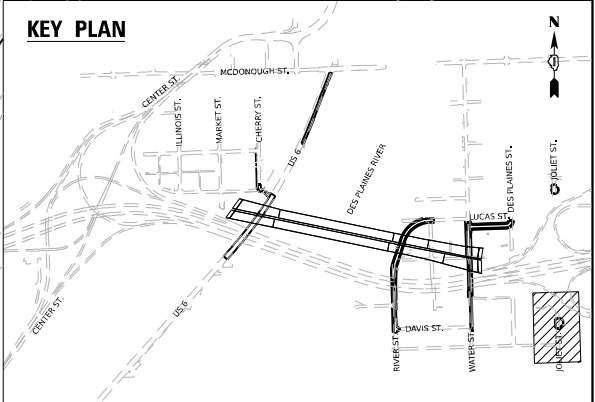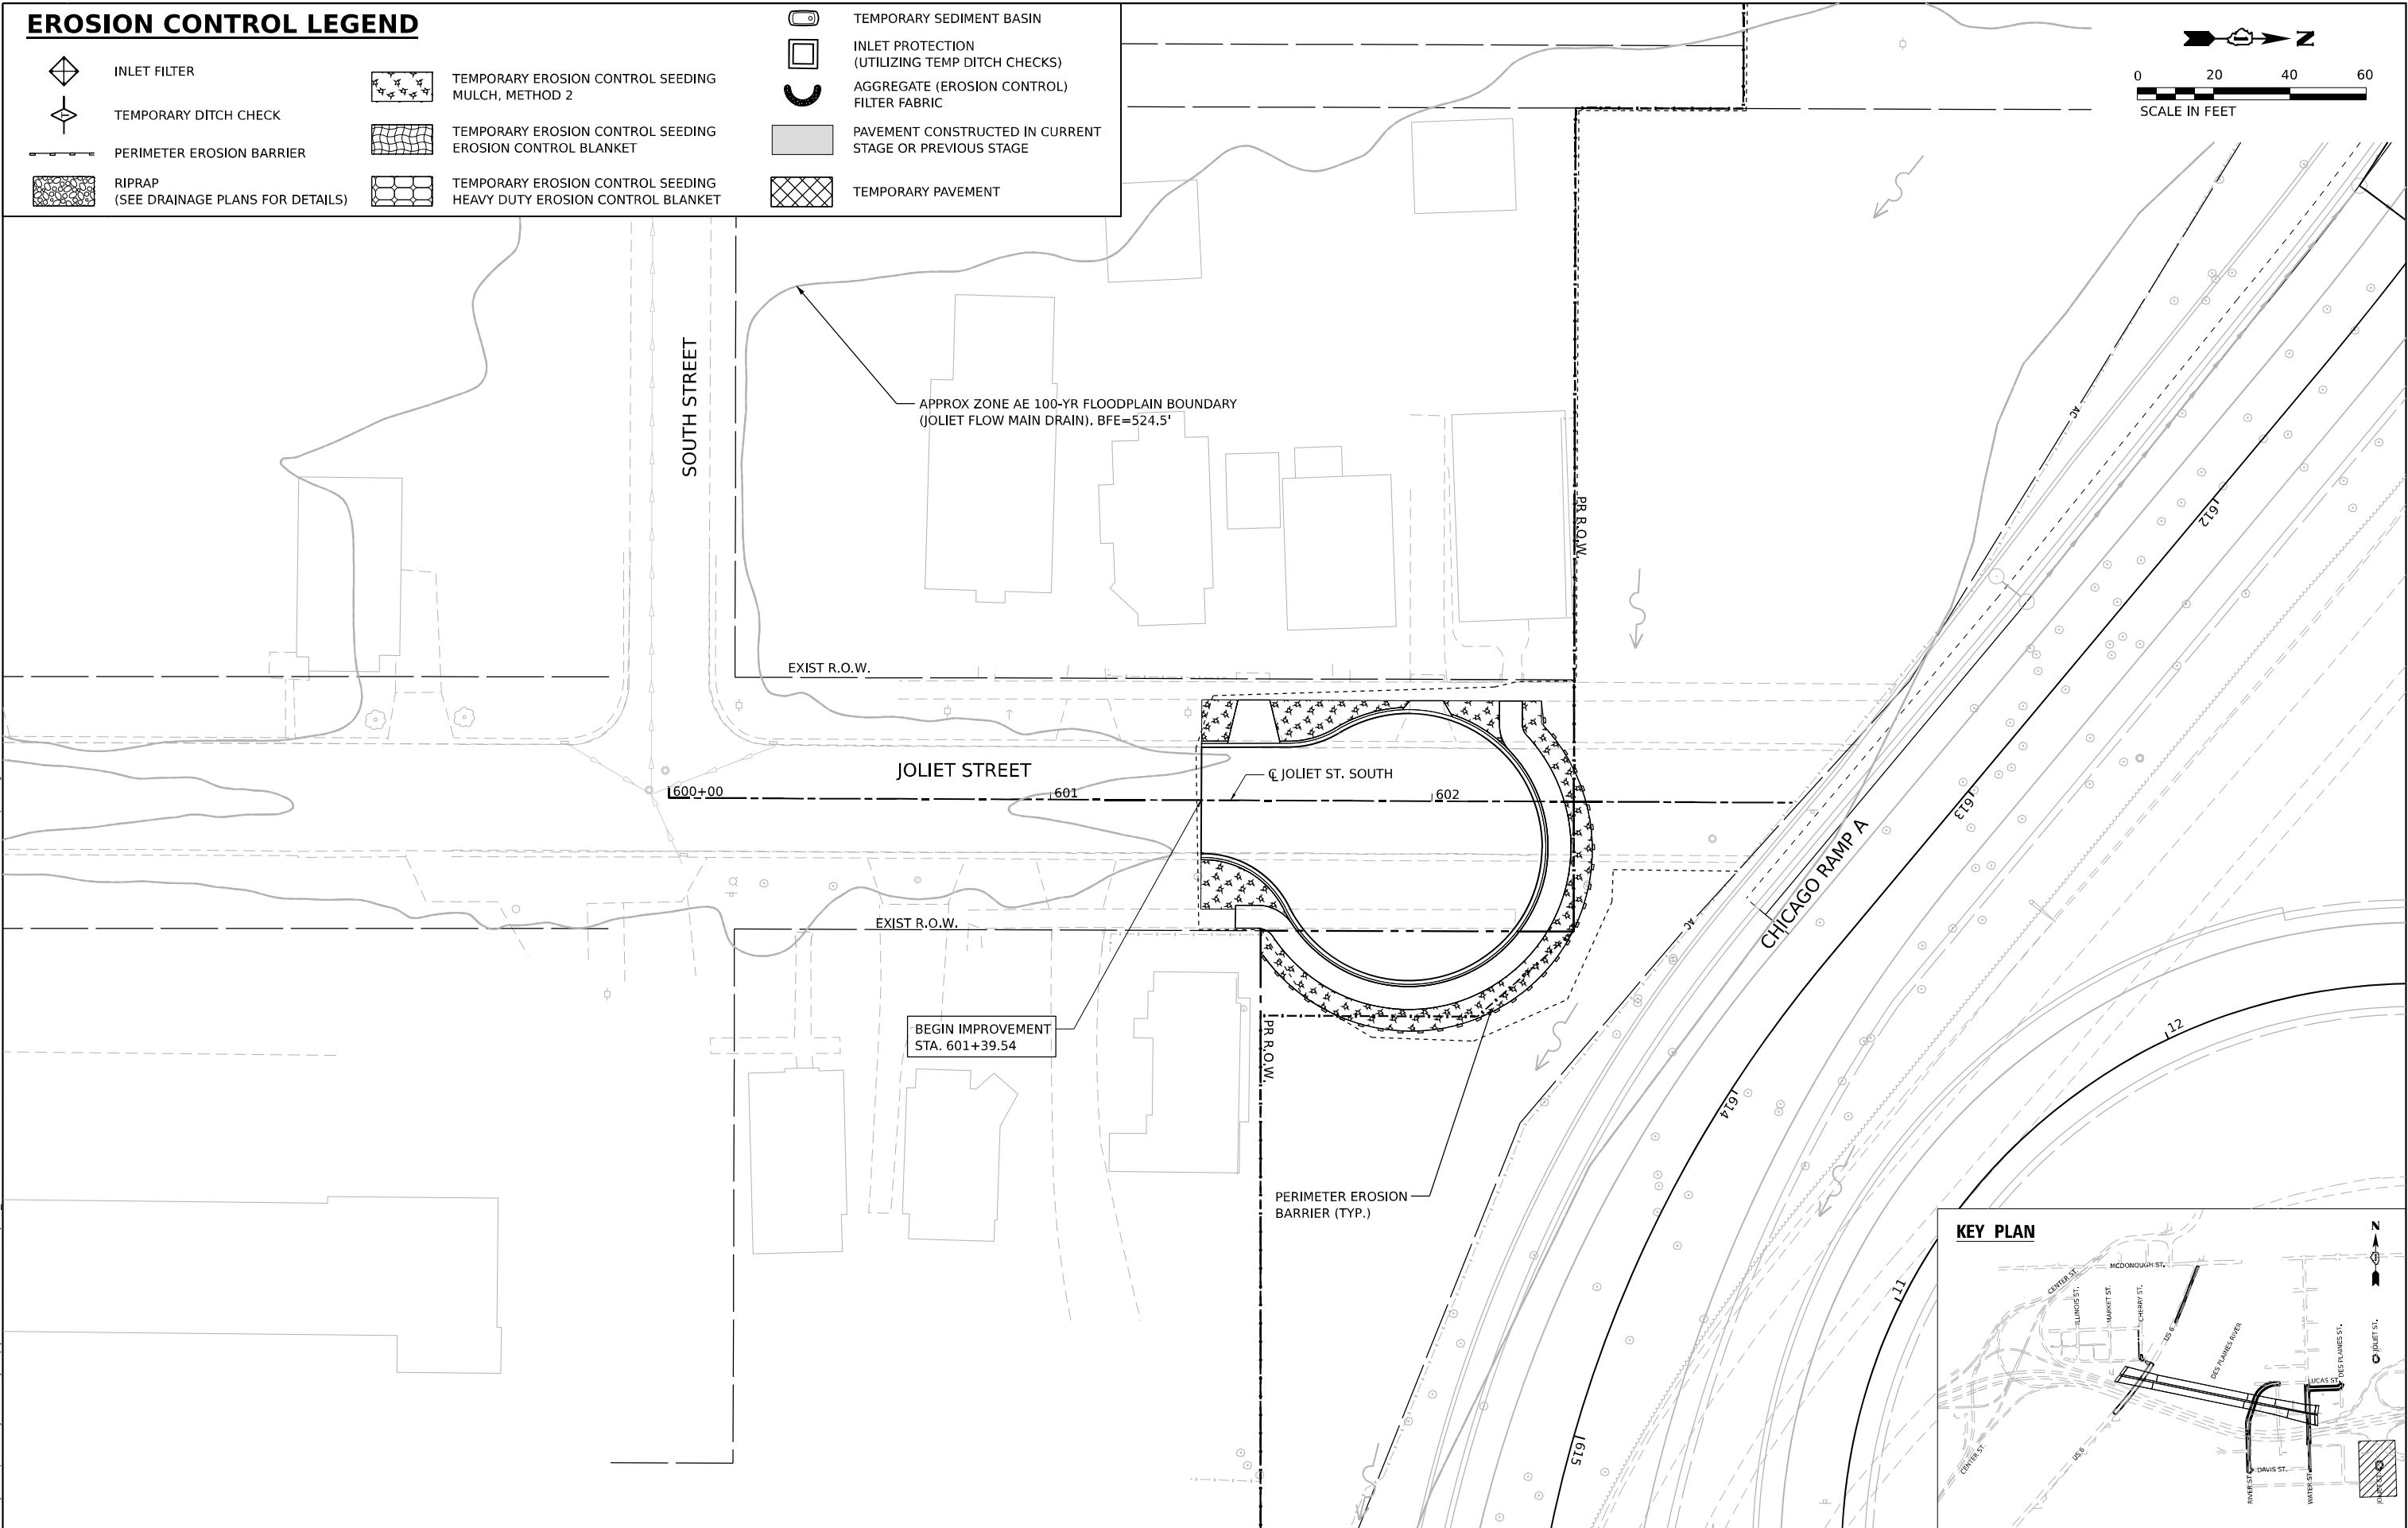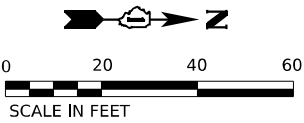

 WSP USA INC. 30 N. LA SALLE STREET SUITE 4200 CHICAGO, IL 60602 TEL: (312) 782-8150	USER NAME = USHC706648		DESIGNED -	REVISED -	STATE OF ILLINOIS DEPARTMENT OF TRANSPORTATION	EROSION CONTROL PLAN JOLIET STREET – SOUTH			F.A.I. RTE.	SECTION	COUNTY	TOTAL SHEETS	SHEET NO.
	DRAWN -		CHECKED -	REVISED -		SCALE: 1"=20'			80	FAI 80 21 STRUCTURE 2	WILL	1230	319
	PLOT SCALE = 40,000' / in.		DATE - 11/7/2025	REVISED -		SHEET 11 OF 12 SHEETS			CONTRACT NO. 62R23				
	PLOT DATE = 11/6/2025					TO STA.			ILLINOIS FED. AID PROJECT				

 EROSION CONTROL LEGEND




INLET FILTER

TEMPORARY DITCH CHECK

PERIMETER EROSION BARRIER

 RIPRAP
(SEE DRAINAGE PLANS FOR DETAILS)



TEMPORARY EROSION CONTROL SEEDING MULCH, METHOD 2

TEMPORARY EROSION CONTROL SEEDING
EROSION CONTROL BLANKET

TEMPORARY EROSION CONTROL SEEDING
HEAVY DUTY EROSION CONTROL BLANKET





TEMPORARY SEDIMENT BASIN

INLET PROTECTION (UTILIZING TEMP DITCH CHECKS)


AGGREGATE (EROSION CONTROL)
FILTER FABRIC

PAVEMENT CONSTRUCTED IN CURRENT
STAGE OR PREVIOUS STAGE

TEMPORARY PAVEMENT

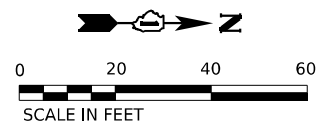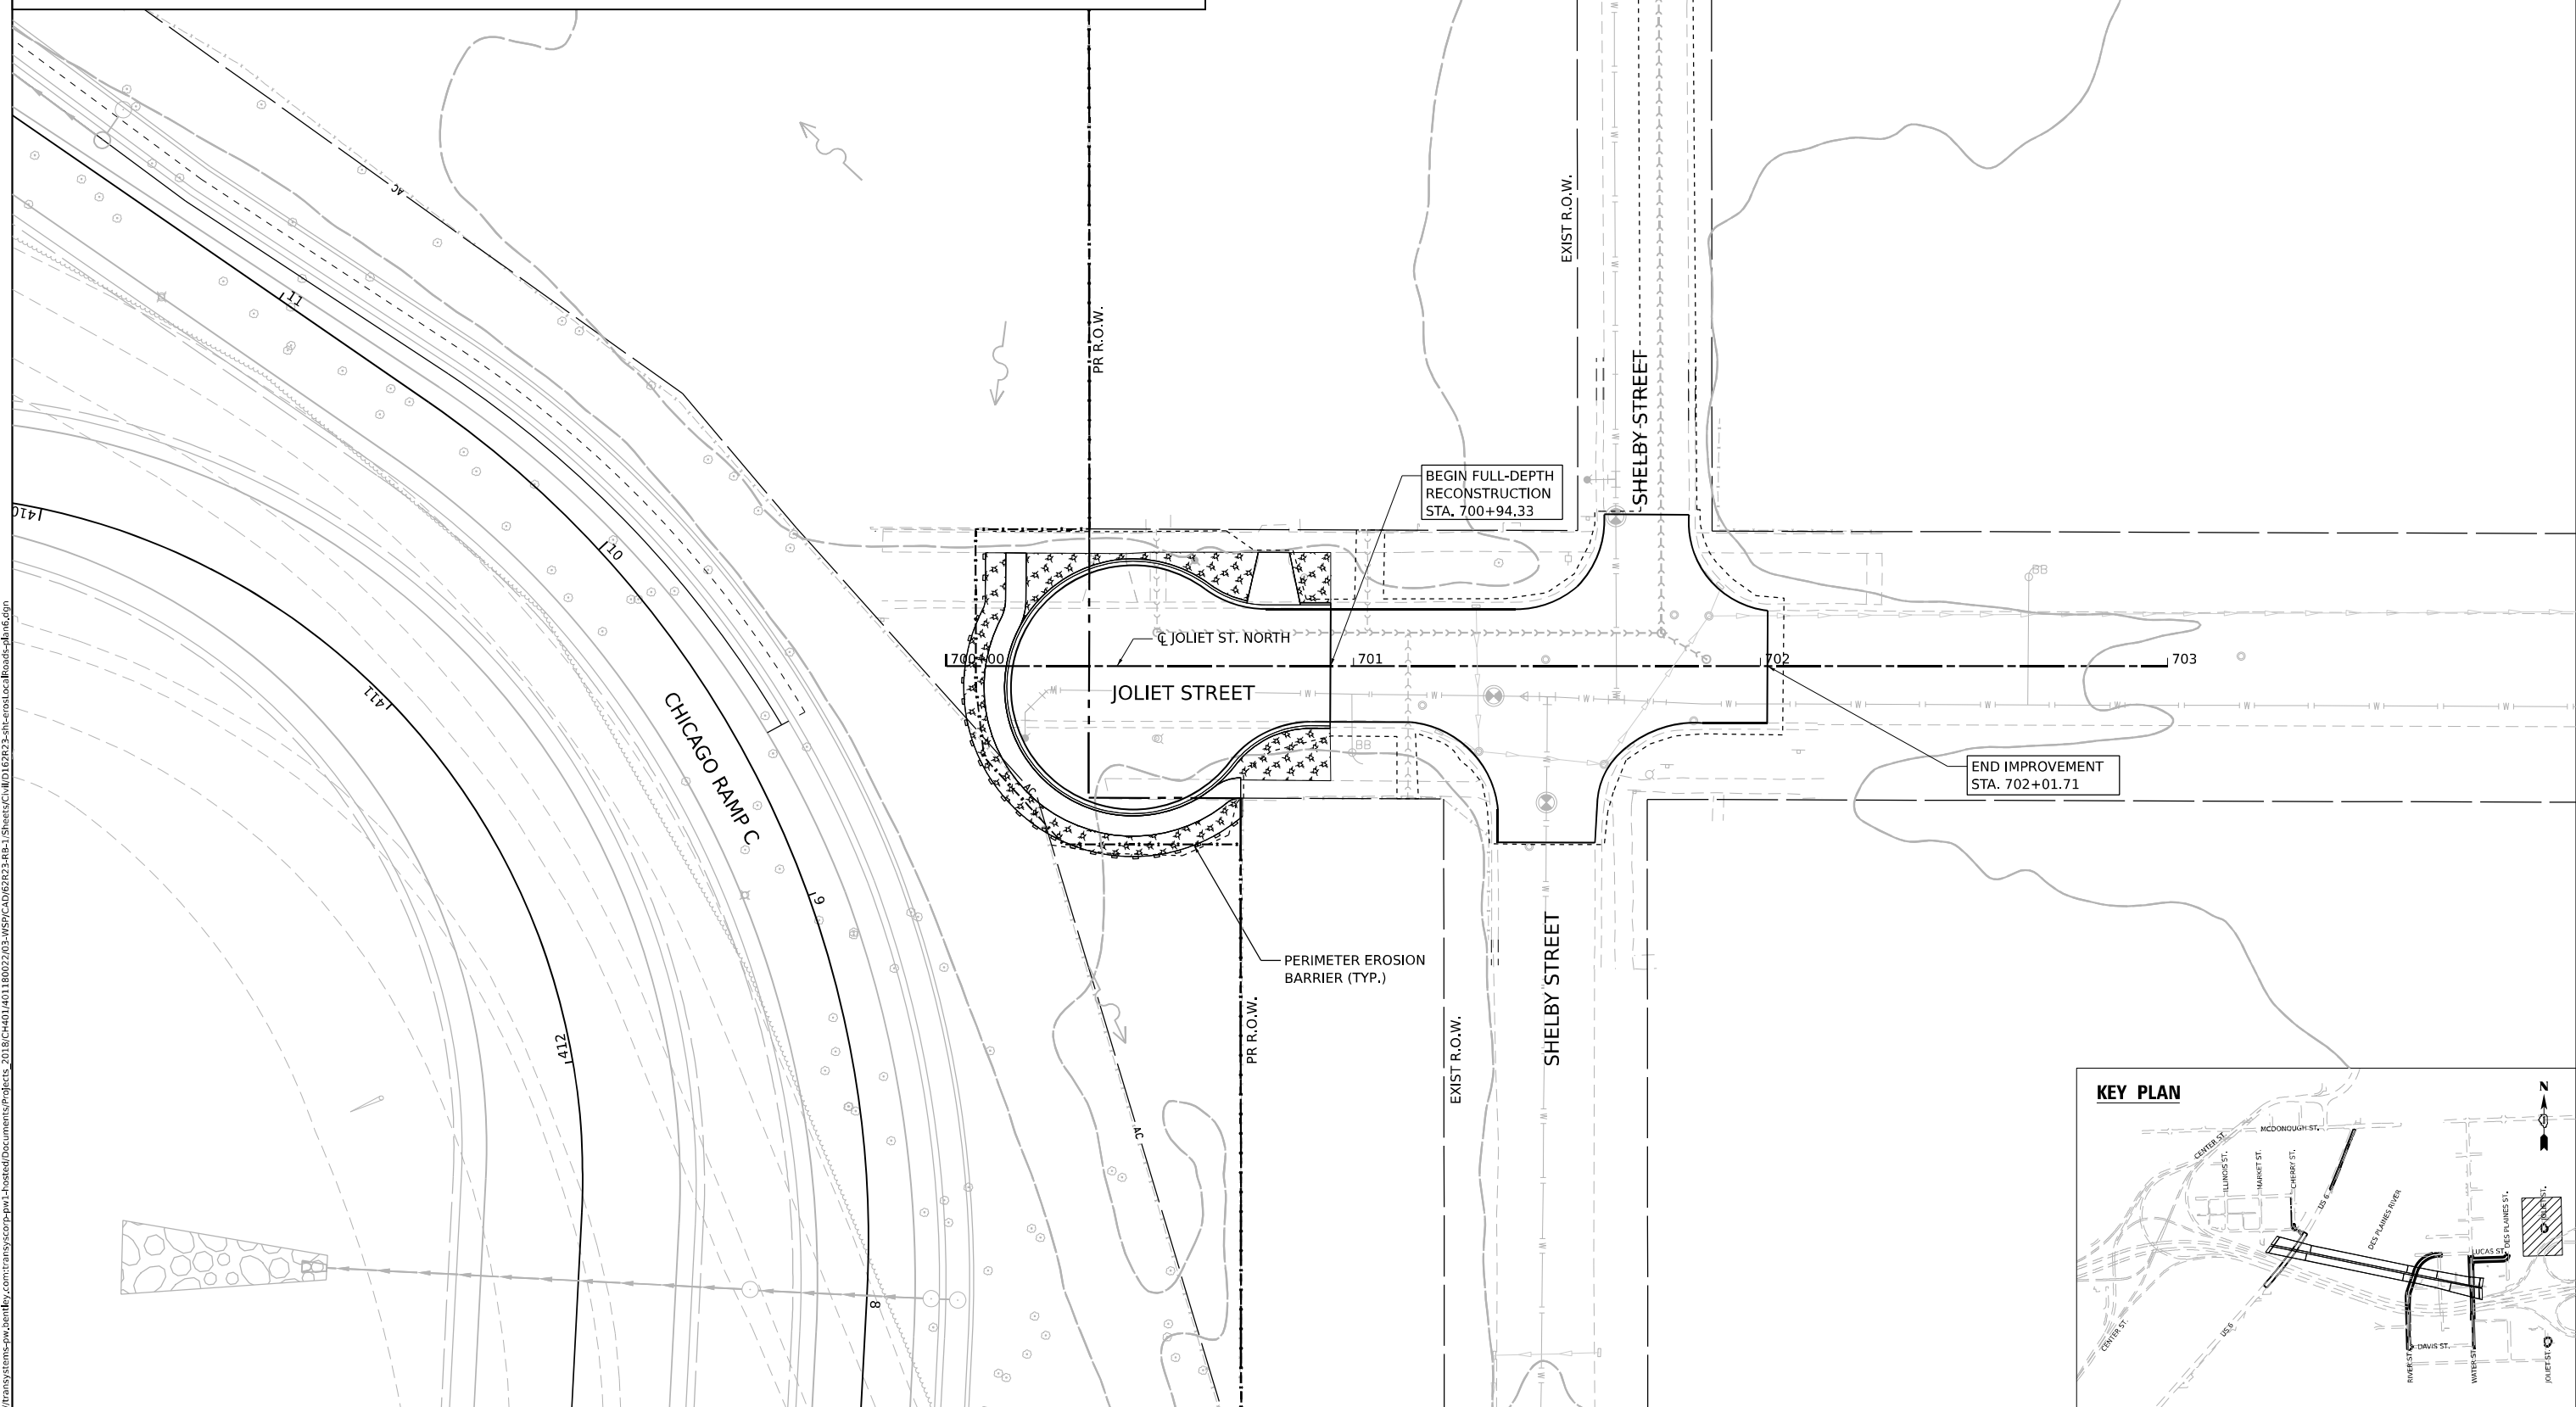

KEY PLAN

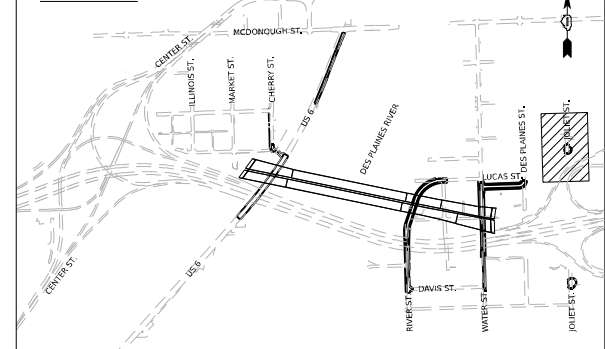

**STATE OF ILLINOIS
DEPARTMENT OF TRANSPORTATION**

EROSION CONTROL PLAN
JOLIET STREET – NORTH

SCALE: 1"=20'

SHEET 12 OF 12 SHEETS

STA.	
------	--

TO STA.

F.A.I. RTE.	SECTION	COUNTY	TOTAL SHEETS	SHEET NO.
80	FAI 80 21 STRUCTURE 2	WILL	1230	320
		CONTRACT NO. 62R23		
		ILLINOIS	FED. AID PROJECT	

MODEL: Default
FILE NAME: pwt\transys\comp-pw-l\hosted\Documents\Projects_2018\CH401\401180022\03-WSP\CAD\62R23-RB-1\Sheets\Civil\DI162R23-silt-eros\LocalRoads-plan.dgn



WSP USA Inc.
30 N. LASALLE STREET
SUITE 4200
CHICAGO, IL 60602
TEL: (312) 782-8150

USER NAME	= USHC706648
-----------	--------------

PLOT SCALE = 40,000' / in.

PLOT DATE 11/6/2025

DESIGNED - C

DRAWN	-	X
-------	---	---

CHECKED - D

DATE	- 1
------	-----



REVISÉ -

REVISÉ -


REVISÉ -

REVISÉ -

EXISTING DRAINAGE & UTILITY LEGEND

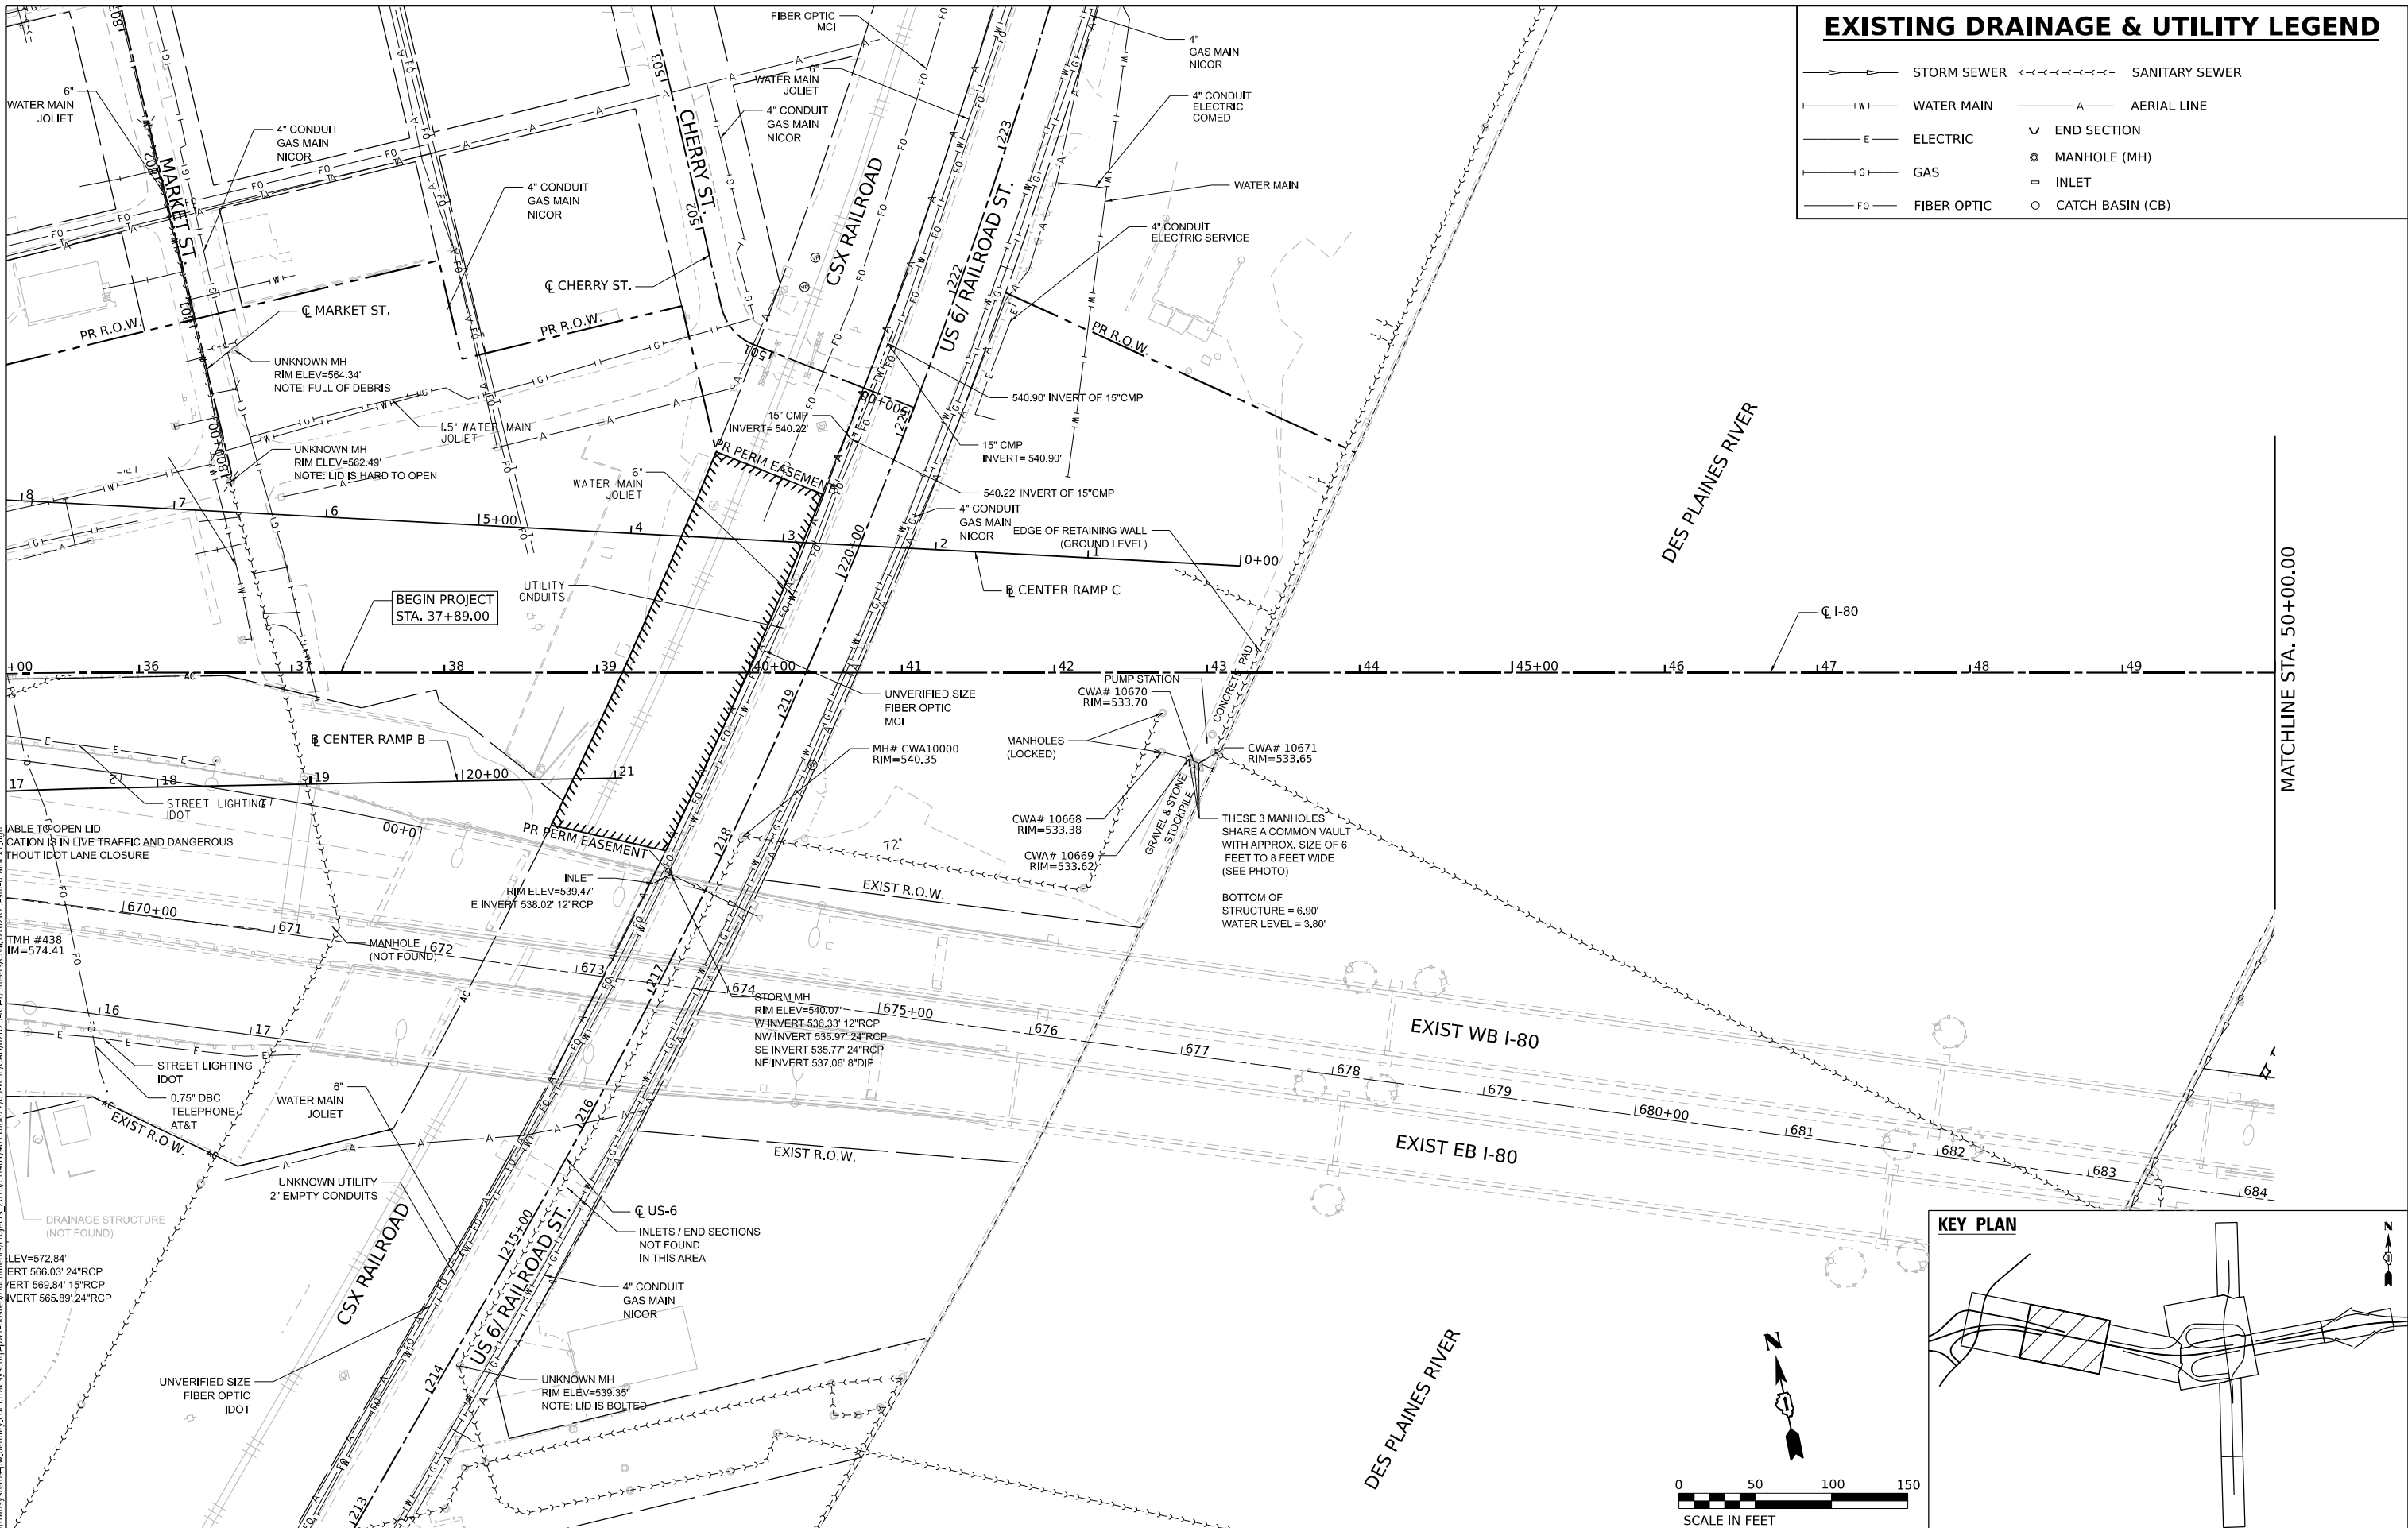
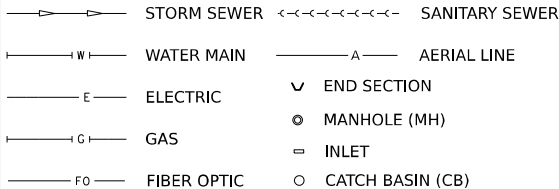


wspr MODEL: Default FILE NAME: p:\projects\transsystems-pw-bentley.com\transcorp-pw\hatched\documents\projects_2018\CH4001401180022\03\WSP\CD\62R23-RB-1\Sheet\CD\62R23-RB-1.dgn WSP USA INC. 30 N. LA SALLE STREET SUITE 4200 CHICAGO, IL 60602 TEL: (312) 782-8150	USER NAME = USHC706648	DESIGNED - SSM	REVISED -	STATE OF ILLINOIS DEPARTMENT OF TRANSPORTATION	EXISTING DRAINAGE AND UTILITIES PLAN			F.A.I. RTE.	SECTION	COUNTY	TOTAL SHEETS	SHEET NO.
	PLOT SCALE = 100,000' / in.	DRAWN - CC	REVISED -		I-80			80	FAI 80 21 STRUCTURE 2	WILL	1230	321
	PLOT DATE = 11/6/2025	CHECKED - HC	REVISED -		SCALE: 1" = 50'			CONTRACT NO. 62R23				
		DATE - 11/7/2025	REVISED -		SHEET 1 OF 4 SHEETS STA. TO STA.			ILLINOIS FED. AID PROJECT				

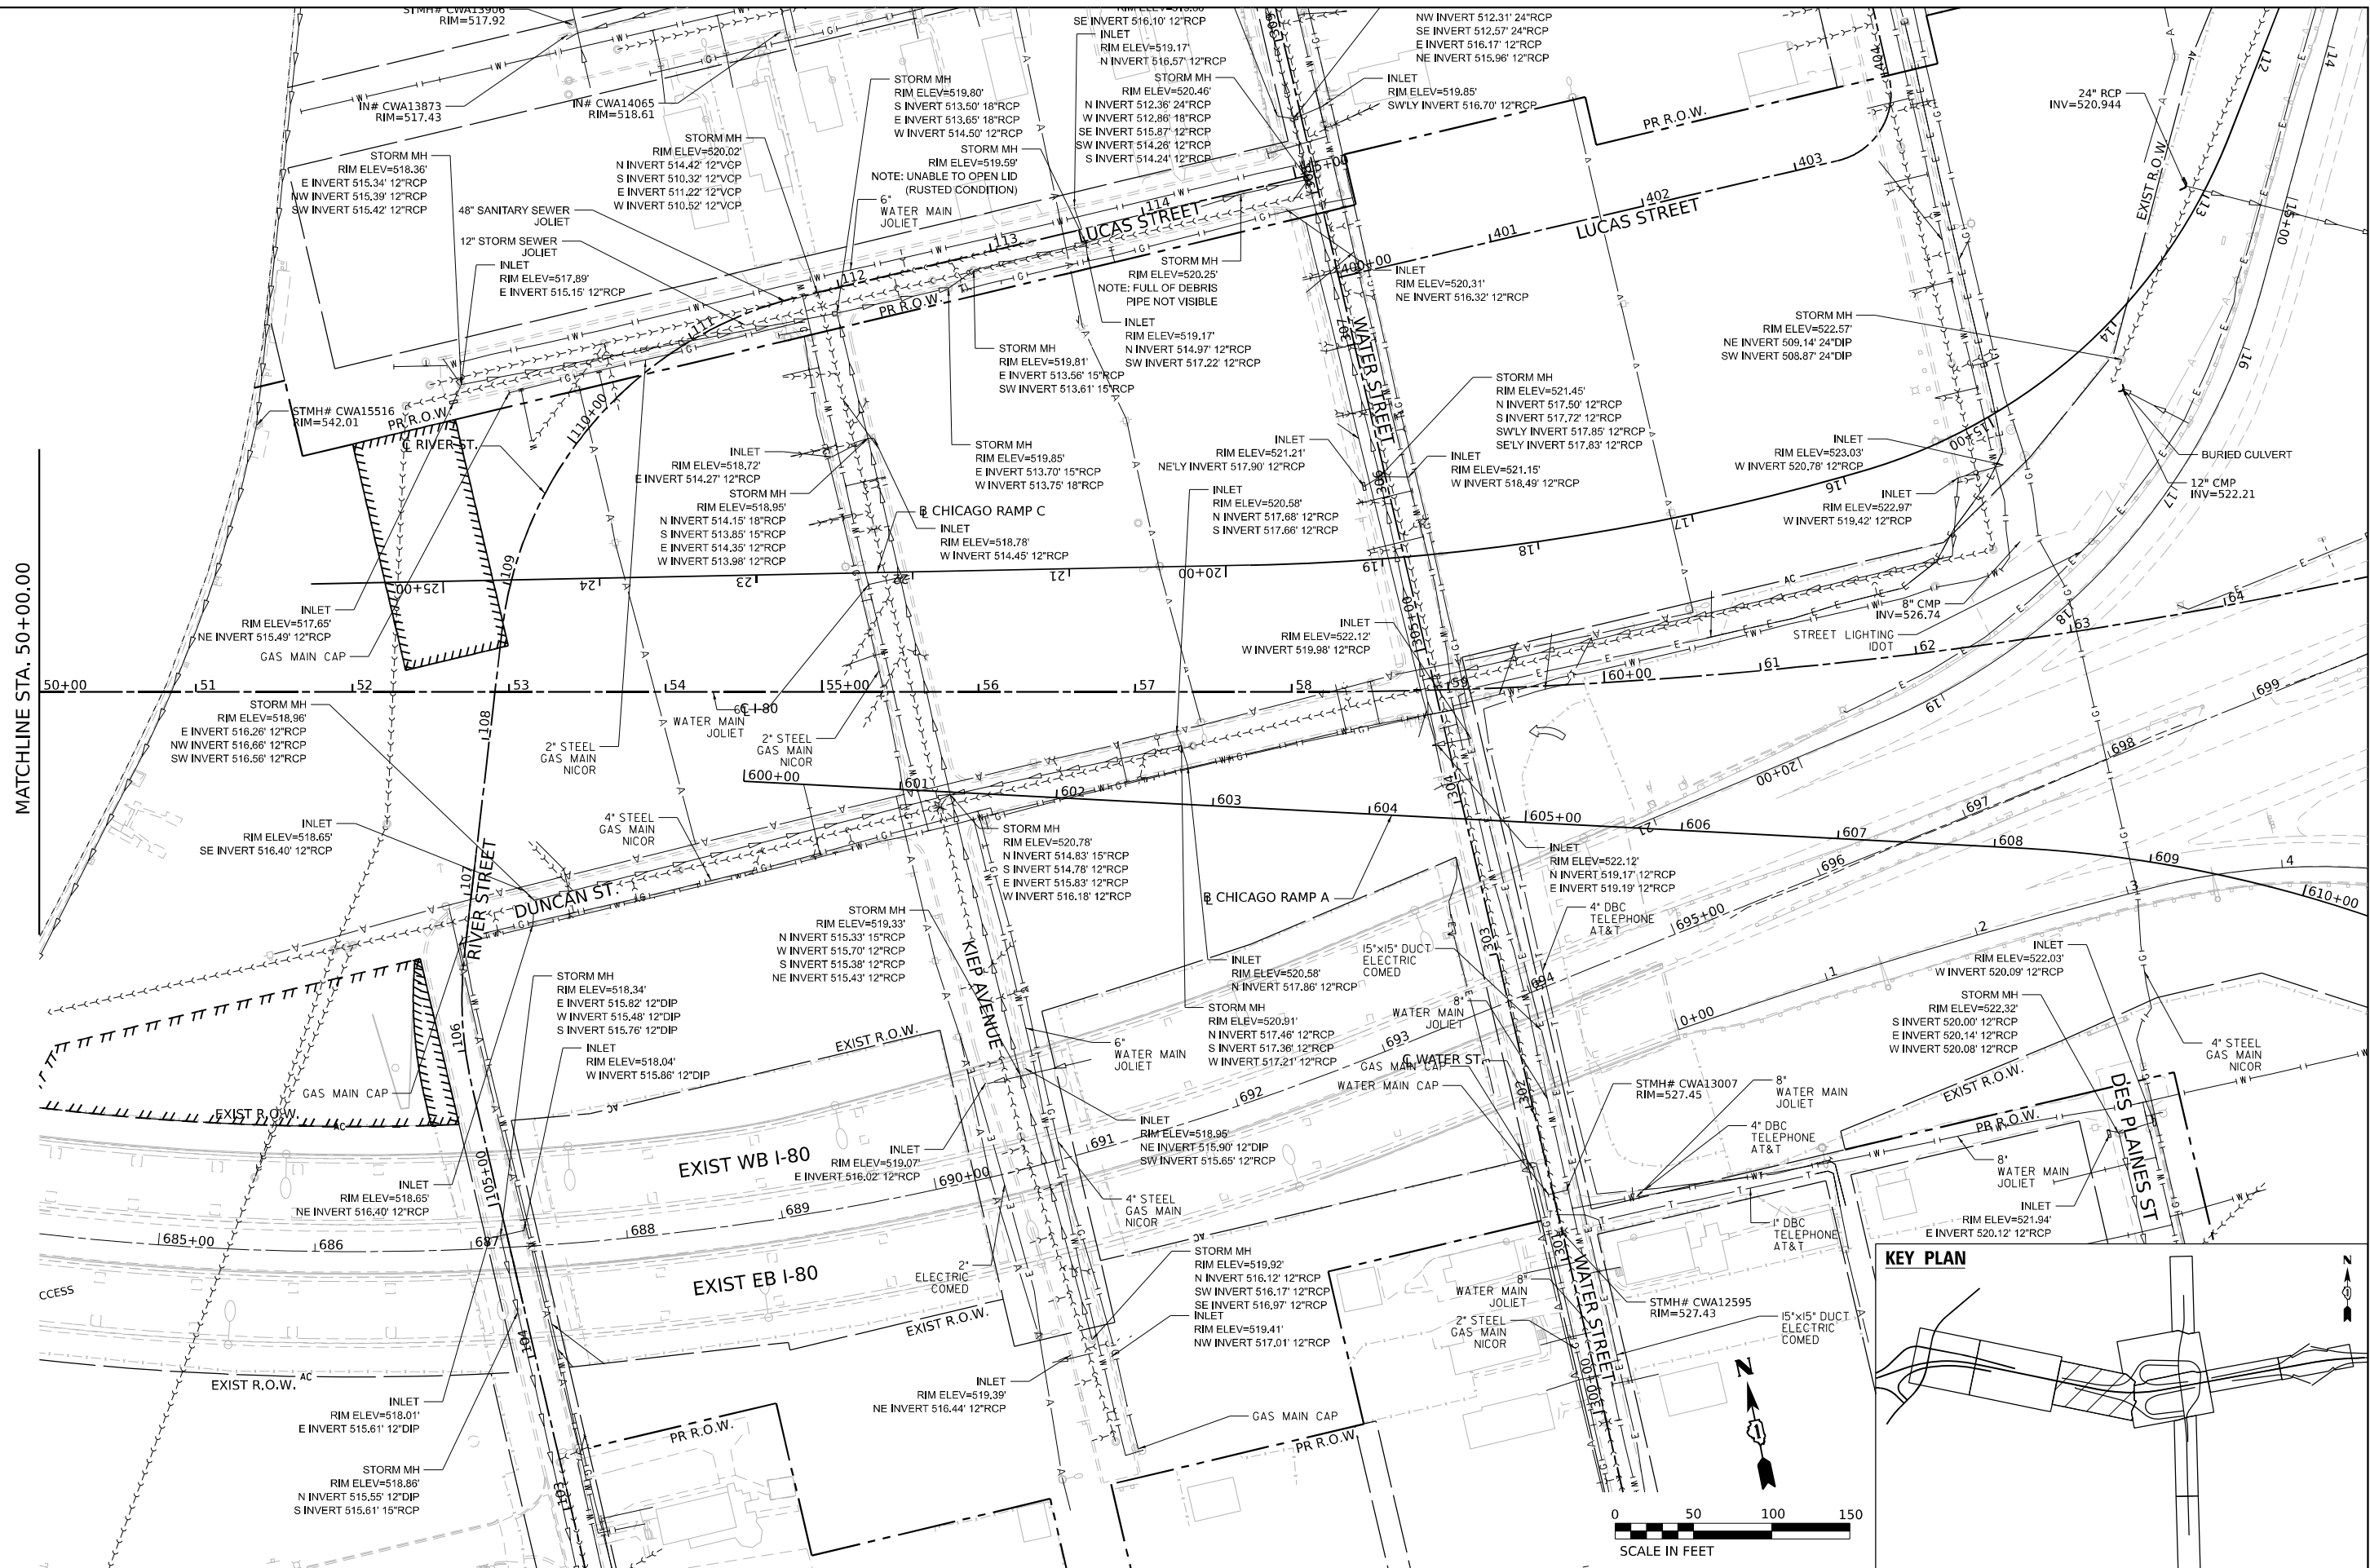


 WSP USA INC. 30 N. LASALLE STREET SUITE 4200 CHICAGO, IL 60602 TEL: (312) 782-9150	USER NAME = USHC706648	DESIGNED - SSM	REVISED -	STATE OF ILLINOIS DEPARTMENT OF TRANSPORTATION	EXISTING DRAINAGE AND UTILITIES PLAN I-80				F.A.I. RTE.	SECTION	COUNTY	TOTAL SHEETS	SHEET NO.
	PLOT SCALE = 100,000 ' / in.	DRAWN - CC	REVISED -						80	FAI 80 21 STRUCTURE 2	WILL	1230	322
	PLOT DATE = 11/6/2025	CHECKED - HC	REVISED -		CONTRACT NO. 62R23								
		DATE - 11/7/2025	REVISED -		SCALE: 1" = 50' SHEET 2 OF 4 SHEETS STA. TO STA.								

KEY PLAN

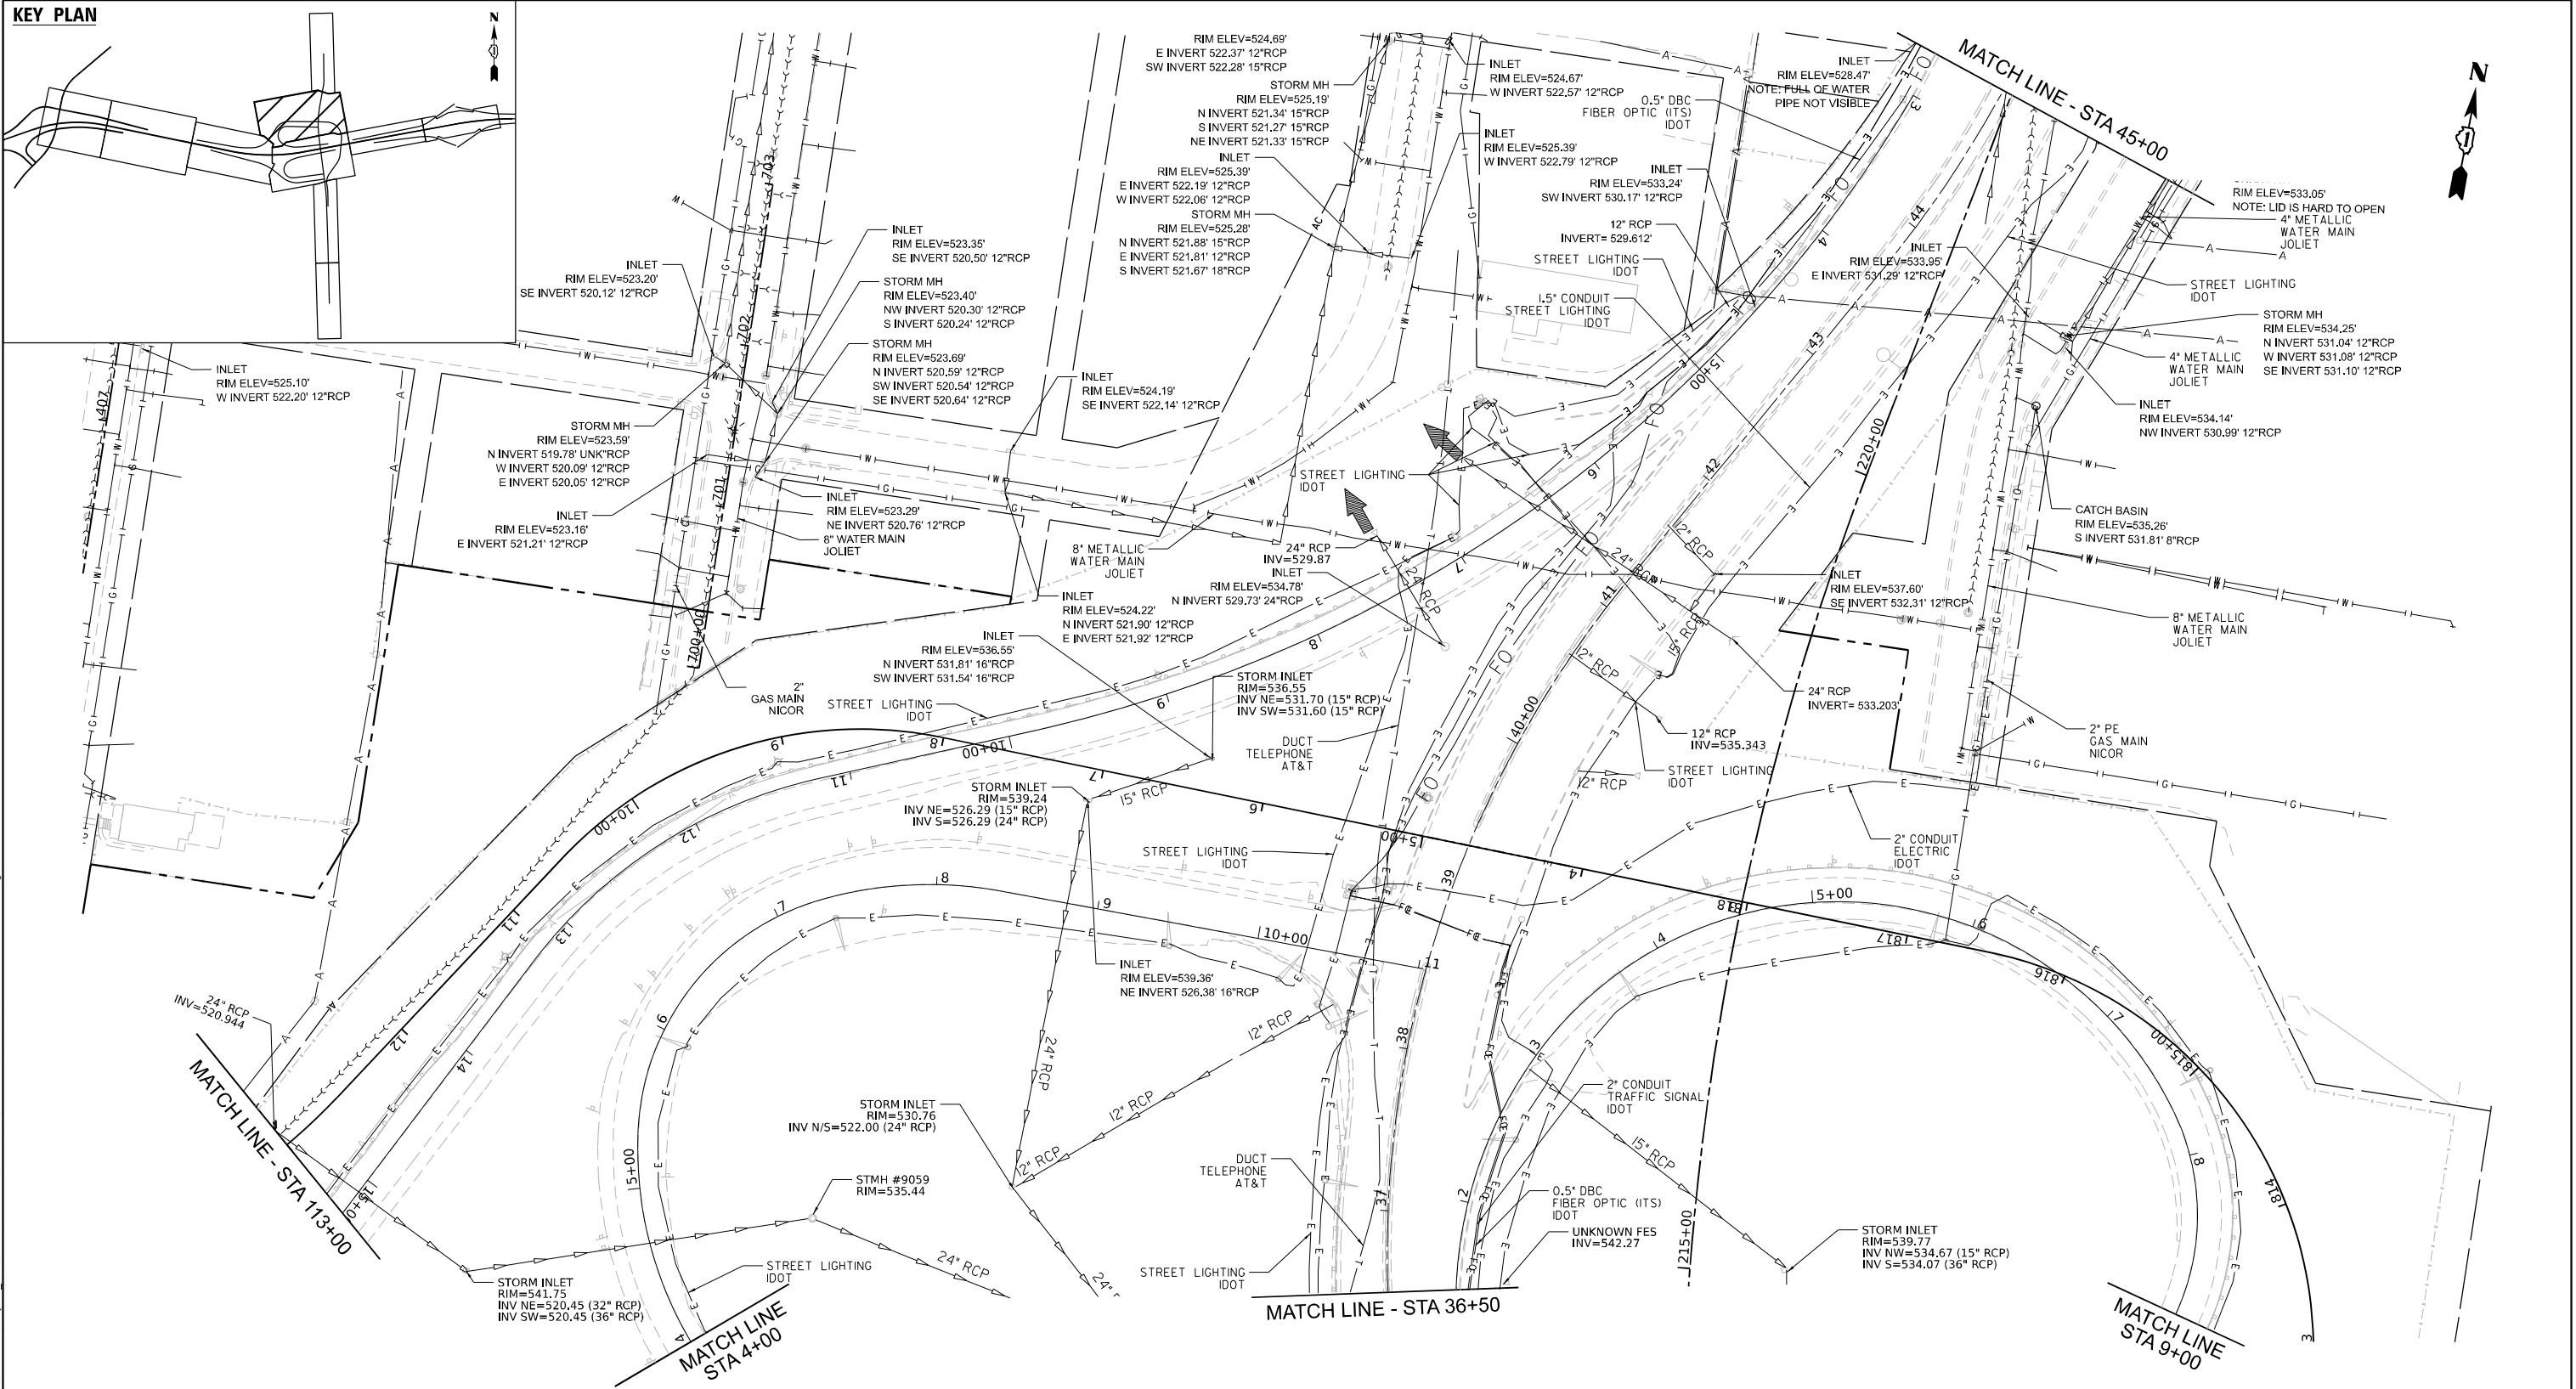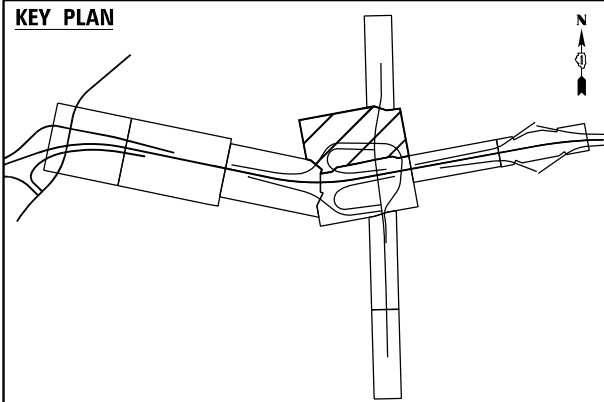

EXISTING DRAINAGE & UTILITY LEGEND

 - STORM SEWER
- SANITARY SEWER
- WATER MAIN
- AERIAL LINE
- ELECTRIC
- END SECTION
- GAS
- MANHOLE (MH)
- FIBER OPTIC
- INLET
- CATCH BASIN (CB)



STATE OF ILLINOIS
DEPARTMENT OF TRANSPORTATION

EXISTING DRAINAGE AND UTILITIES PLAN
I-80


SCALE: 1" = 50' SHEET 3 OF 4 SHEETS STA. TO STA.

F.A.I. RTE.	SECTION	COUNTY	TOTAL SHEETS	SHEET NO.
80	FAI 80 21 STRUCTURE 2	WILL	1230	323
CONTRACT NO. 62R23				
ILLINOIS FED. AID PROJECT				



MODEL: Default
FILE NAME: p:\projects\trans\trans\ppl\hatched\Documents\projects_2018\CH4001401180022\03-MS9\CD\62R23-RB-1_Sheets\CD\102R23-shd-drawn\2-1.dgn

wsp
WSP USA INC.
30 N. LASALLE STREET
SUITE 4700
CHICAGO, IL 60602
TEL: (312) 782-8150

USER NAME = USHC706648	DESIGNED - SSM	REVISED -
DRAWN - CC	REVISED -	
PLOT SCALE = 100,000' / in.	CHECKED - HC	REVISED -
PLOT DATE = 11/6/2025	DATE - 11/7/2025	REVISED -

 

Model: Default
File Name: p:\projects\trans\trans\ppl\boxed\Documents\projects_2018\CH4001401180022\03-MS9\CAD\62R23-RB-1_Sheets\CH4001401180022-62R23-shd-dp\shd-1.dgn

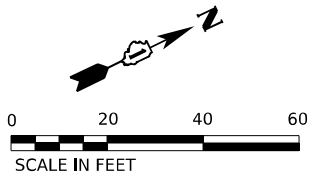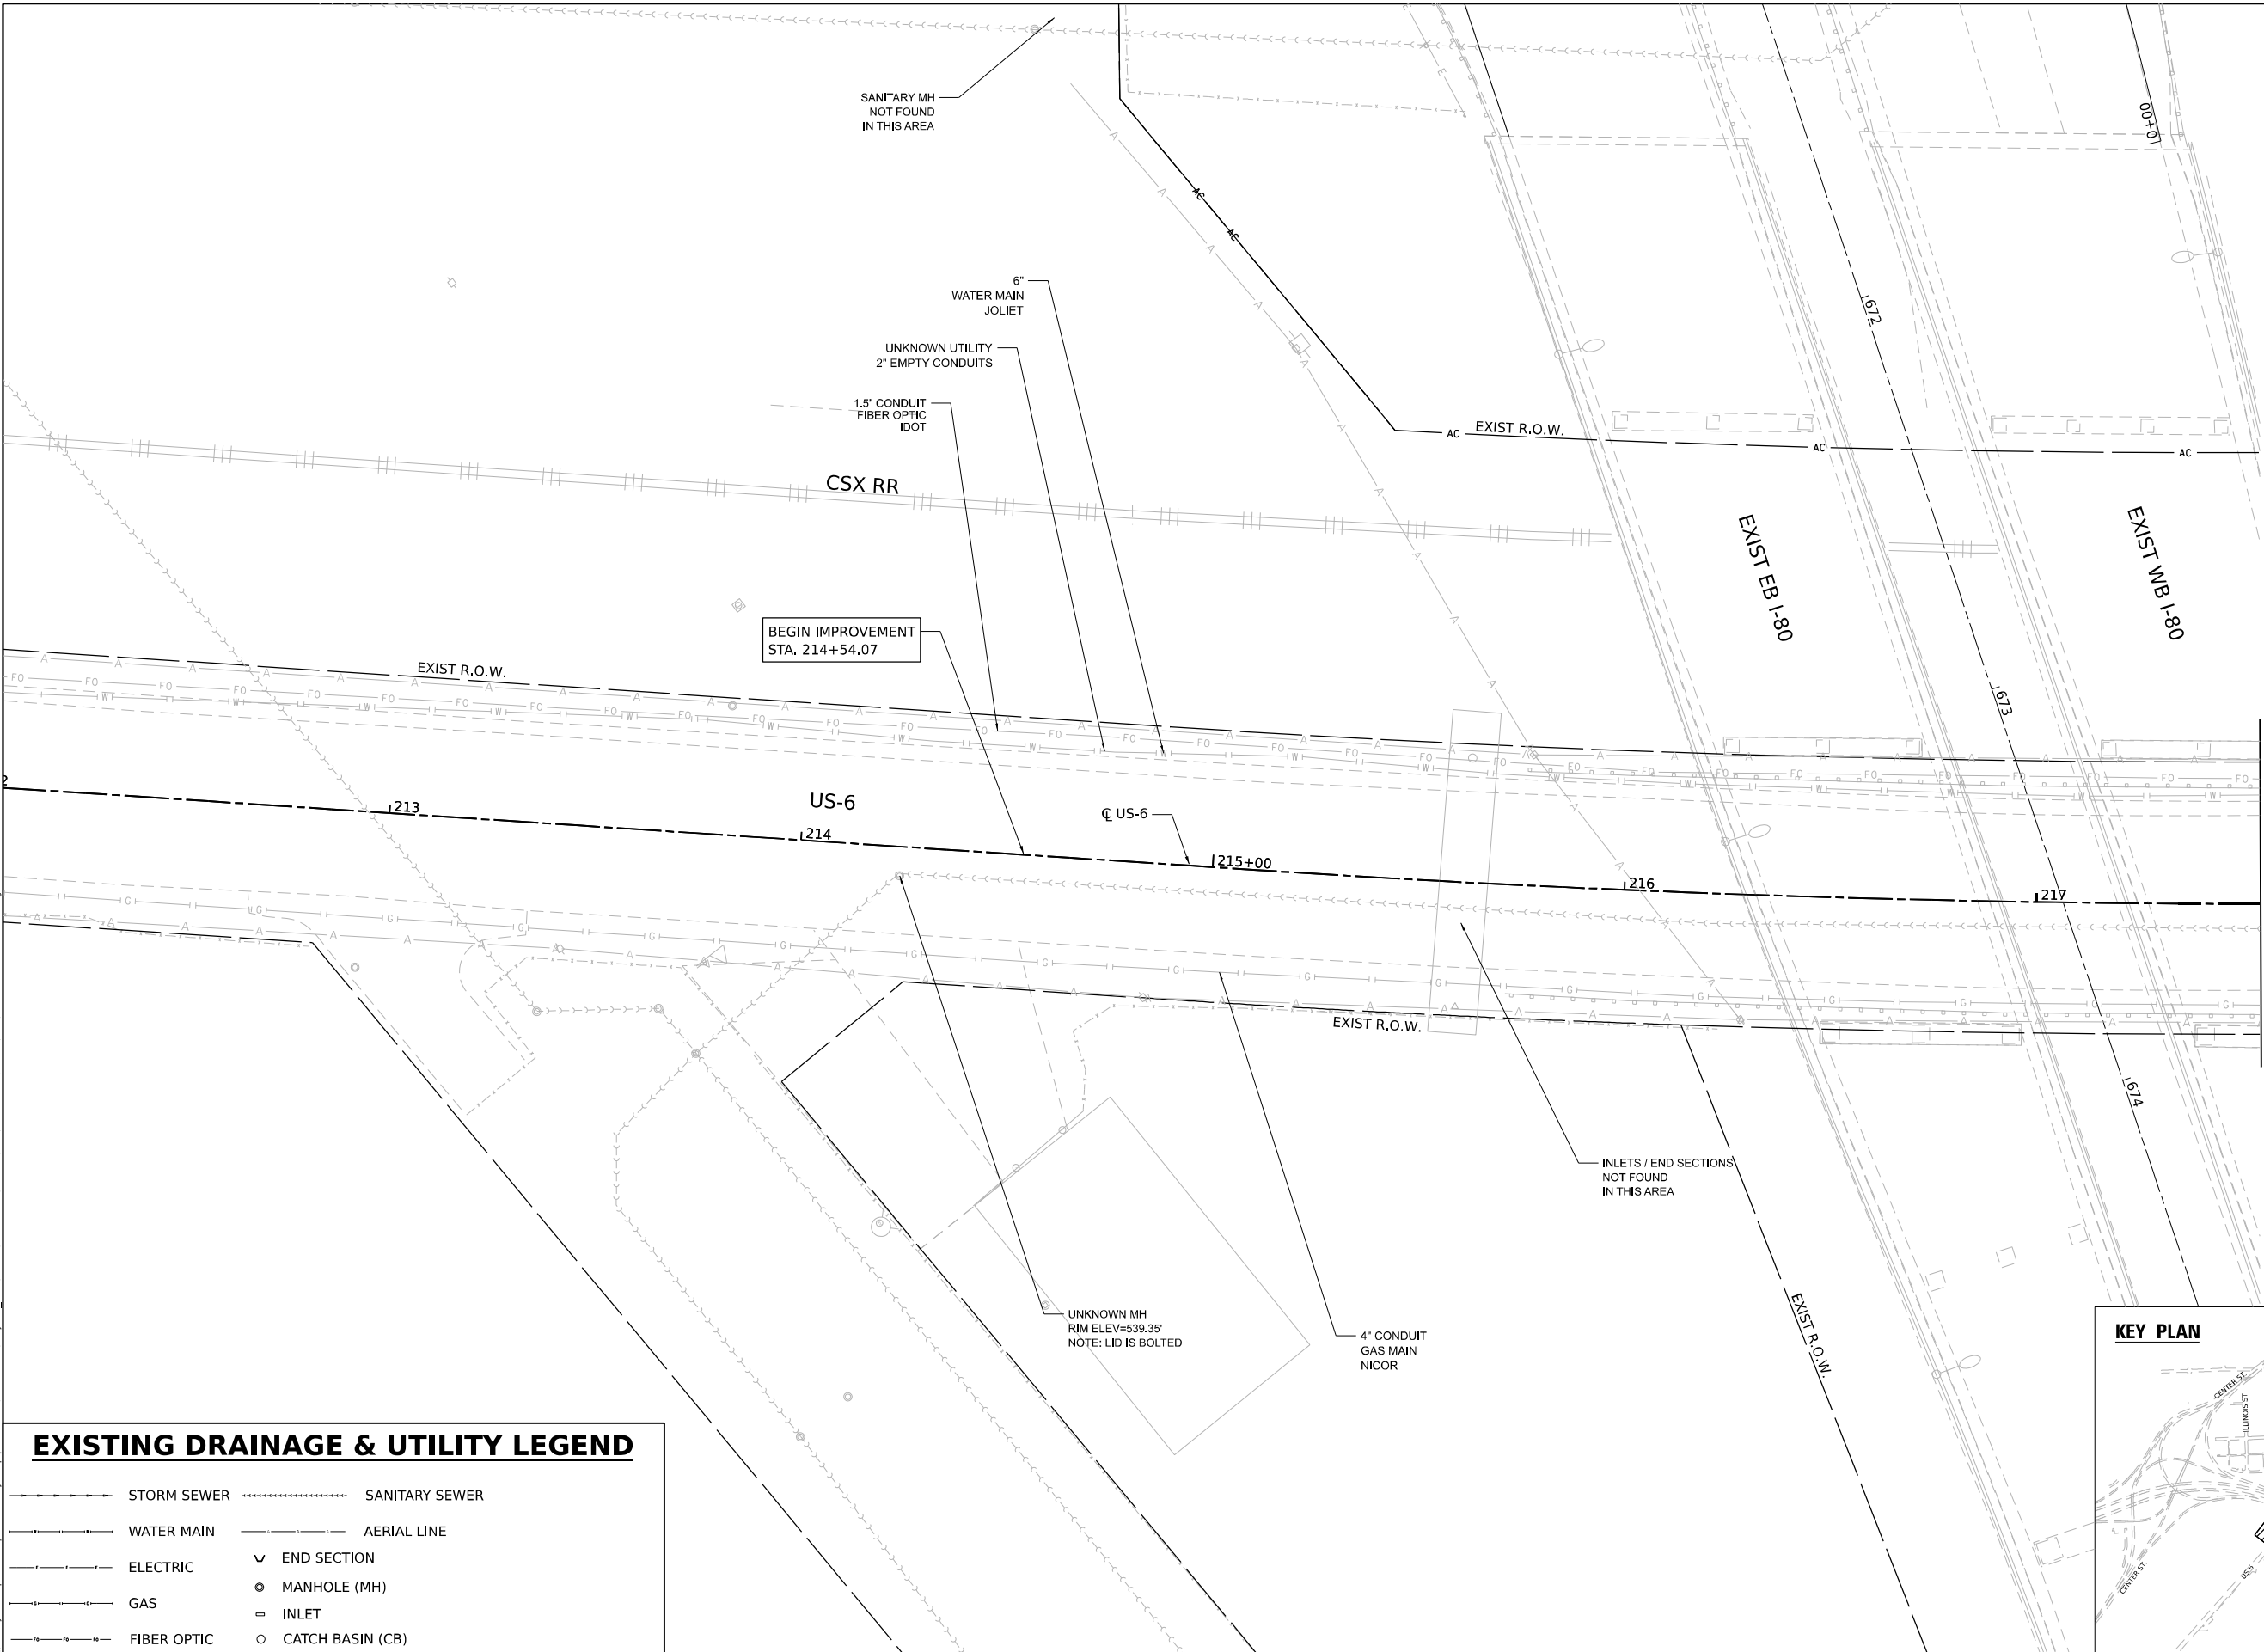

EXISTING DRAINAGE & UTILITY LEGEND

- STORM SEWER
- WATER MAIN
- ELECTRIC
- GAS
- FIBER OPTIC
- SANITARY SEWER
- AERIAL LINE
- END SECTION
- MANHOLE (MH)
- INLET
- CATCH BASIN (CB)



WSP USA INC.
30 N. LASALLE STREET
SUITE 4700
CHICAGO, IL 60602
TEL: (312) 782-8150


USER NAME	= USHC706648
DESIGNED	- SSM
DRAWN	- CC
CHECKED	- HC
DATE	- 11/7/2025
PLOT SCALE	= 40,000' / in.
PLOT DATE	= 11/6/2025

REVISED	-
REVISED	-
REVISED	-
REVISED	-

STATE OF ILLINOIS
DEPARTMENT OF TRANSPORTATION


EXISTING DRAINAGE AND UTILITY PLANS
US-6

SCALE: 1"=20' SHEET 1 OF 12 SHEETS STA. TO STA.

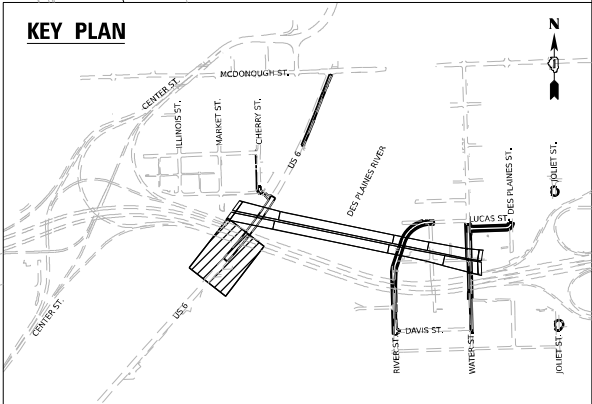

F.A.I. RTE.	SECTION	COUNTY	TOTAL SHEETS	SHEET NO.
80	FAI 80 21 STRUCTURE 2	WILL	1230	325
CONTRACT NO. 62R23				
ILLINOIS FED. AID PROJECT				

Model: Default
File Name: p:\projects\trans\trans\ppl\hatched\Documents\projects_2018\CH4001401180022\03-WSP\CH40014011800223-RB-1_Sheets\CH40014011800223-shh-dp\shh12.dgn

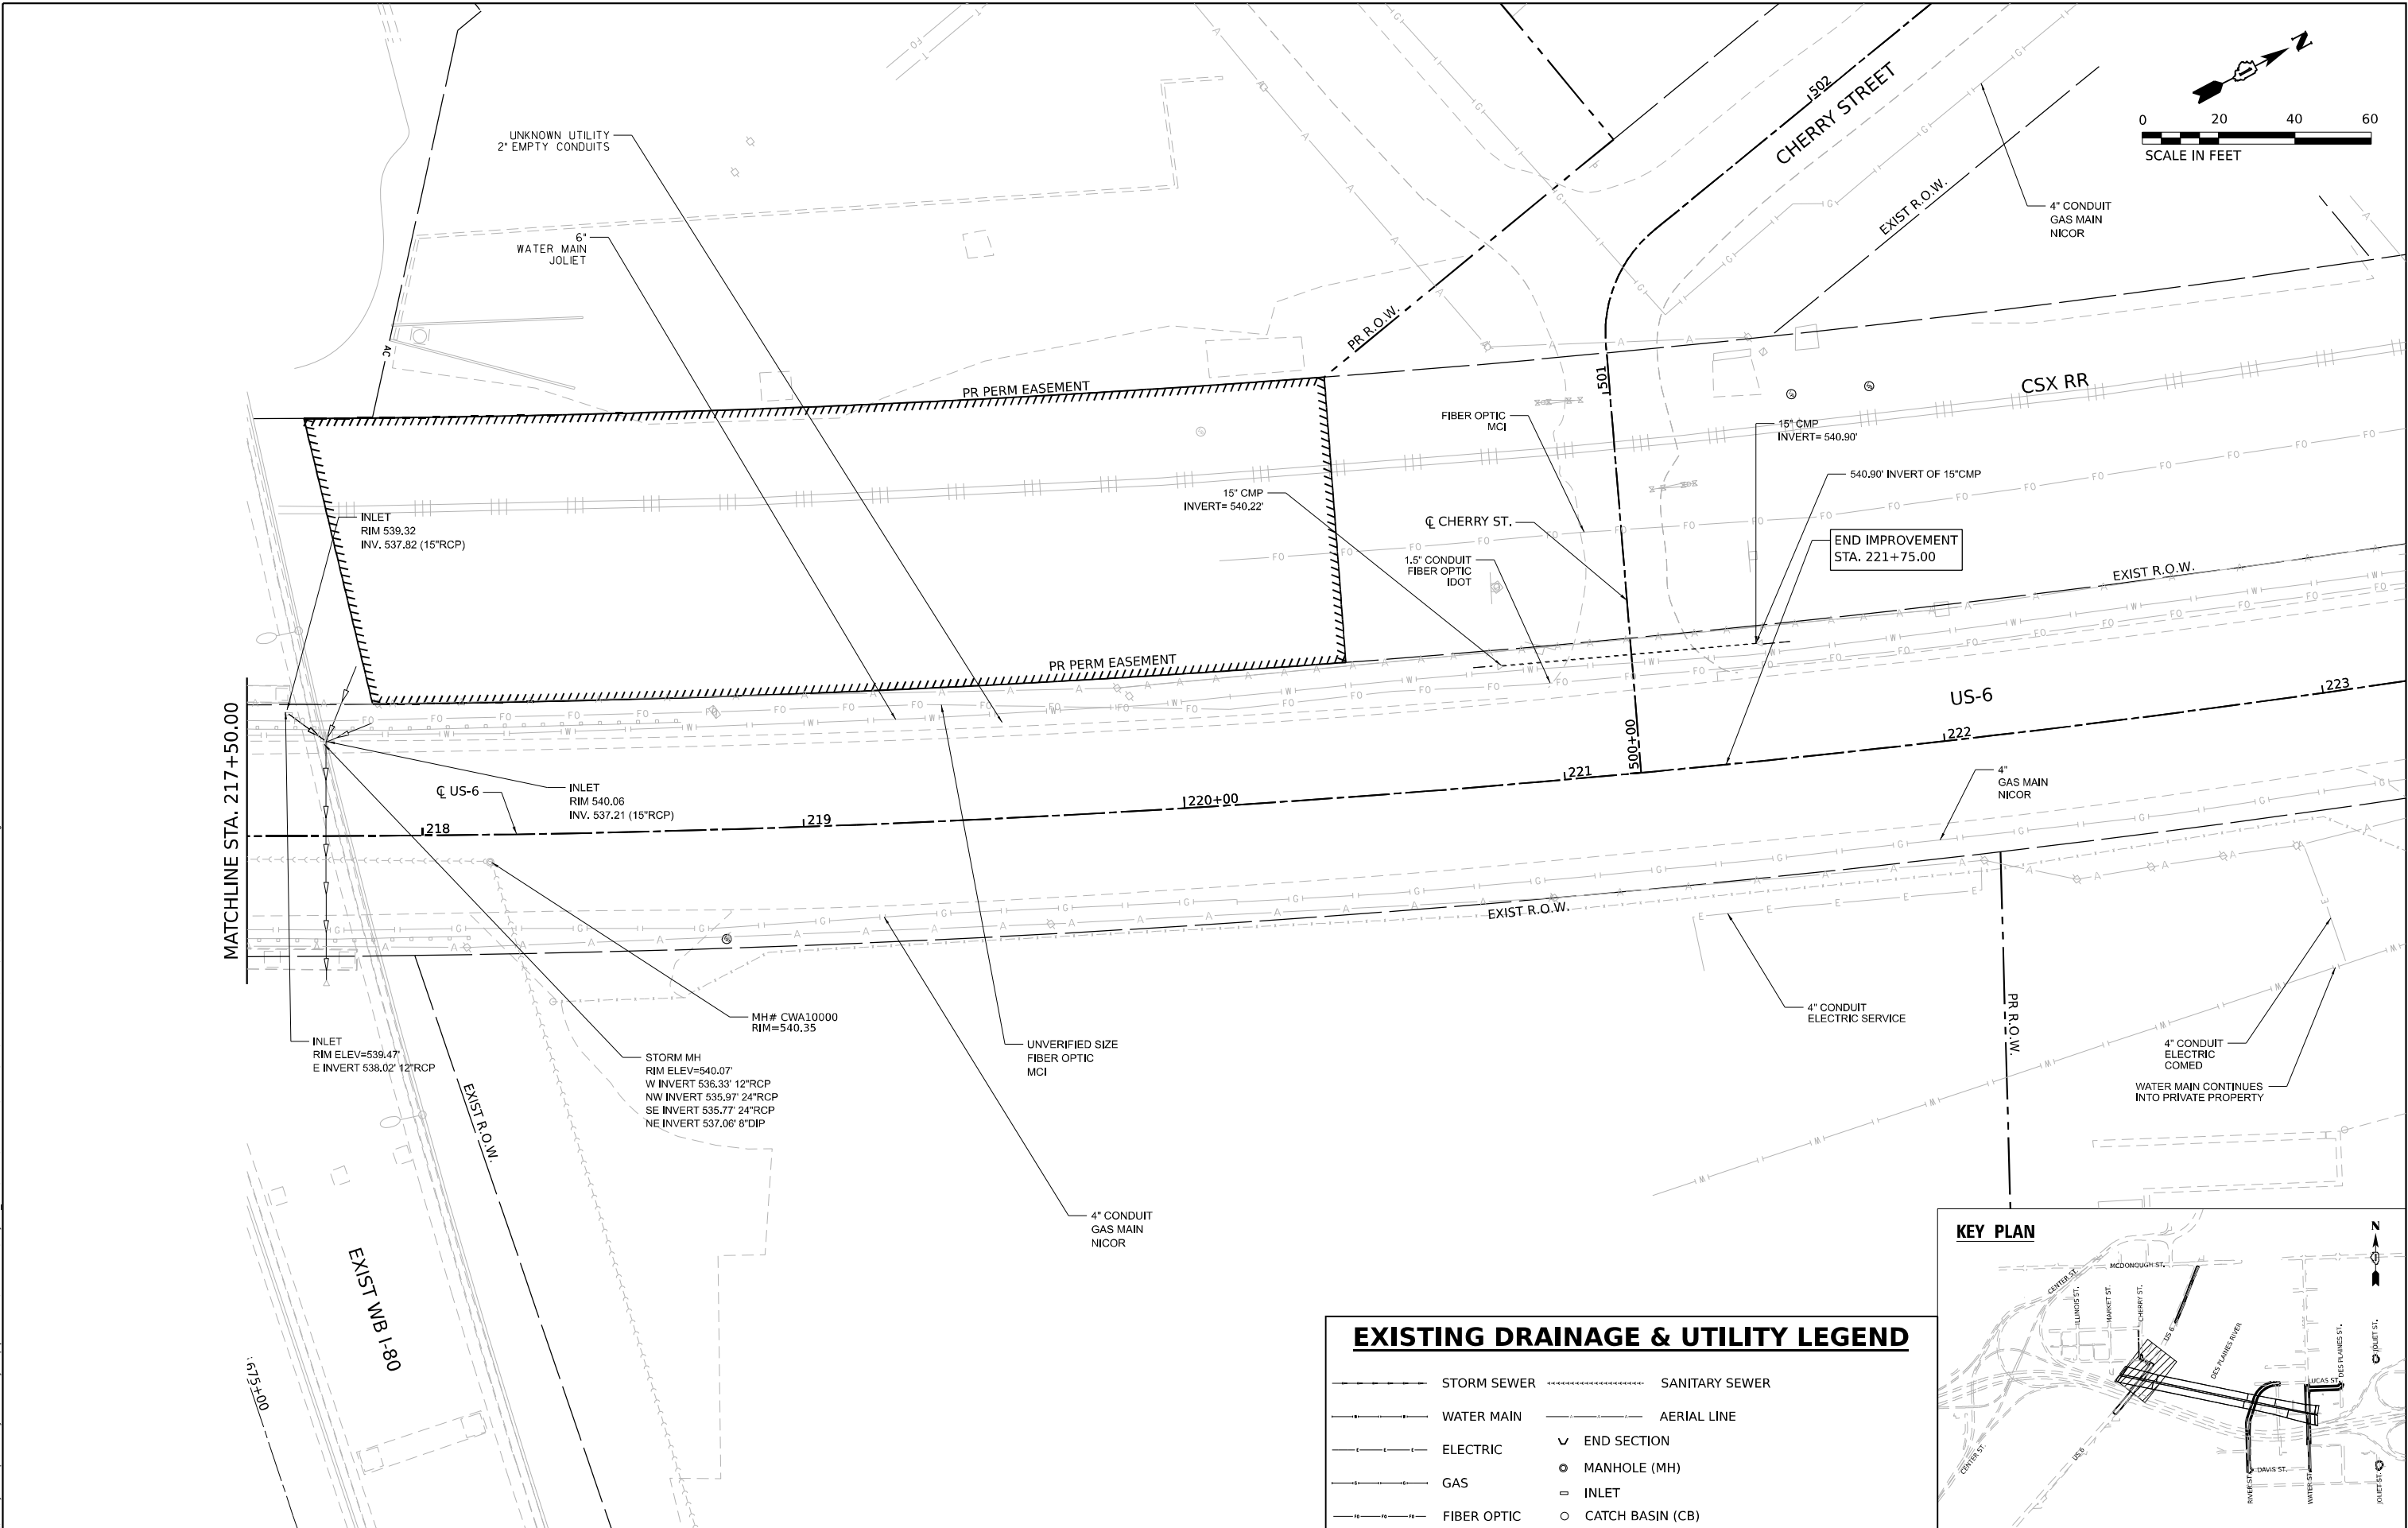

EXISTING DRAINAGE & UTILITY LEGEND

STORM SEWER

WATER MAIN

ELECTRIC

GAS

FIBER OPTIC

SANITARY SEWER


AERIAL LINE

END SECTION

MANHOLE (MH)


INLET

CATCH BASIN (CB)

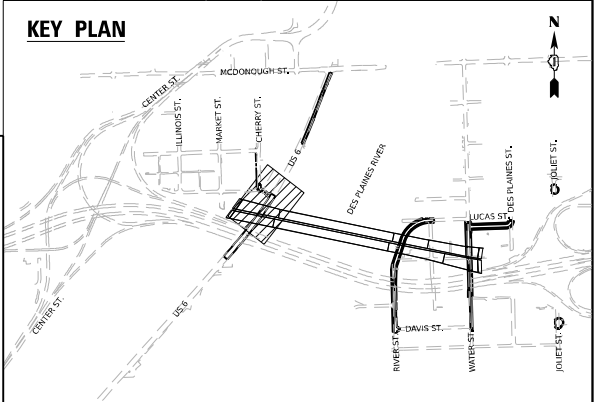


WSP WSP USA Inc. 30 N. LA SALLE STREET SUITE 4200 CHICAGO, IL 60602 TEL: (312) 782-8150	USER NAME = USHC706648		DESIGNED - SSM		REVISED -		STATE OF ILLINOIS DEPARTMENT OF TRANSPORTATION										EXISTING DRAINAGE AND UTILITY PLANS										F.A.I. RTE.	SECTION		COUNTY		TOTAL SHEETS		SHEET NO.								
	DRAWN - CC		REVISED -		US-6												80	FAI 80 21 STRUCTURE 2		WILL		1230		326																		
	PLOT SCALE = 40,000' / in.		CHECKED - HC		REVISED -												SCALE: 1"=20'										SHEET 2 OF 12 SHEETS		STA.		TO STA.		CONTRACT NO. 62R23									
	PLOT DATE = 11/6/2025		DATE - 11/7/2025		REVISED -																												ILLINOIS FED. AID PROJECT									

Model: Default
File Name: p:\trans\stone-pw-bentley.com\trans\corp-pw-l\hatched\Documents\Projects_2018\CH4001401180022\03-WSP\CD\62R23-RB-1_Sheets\CD\62R23-shd-dp\shd13.dgn


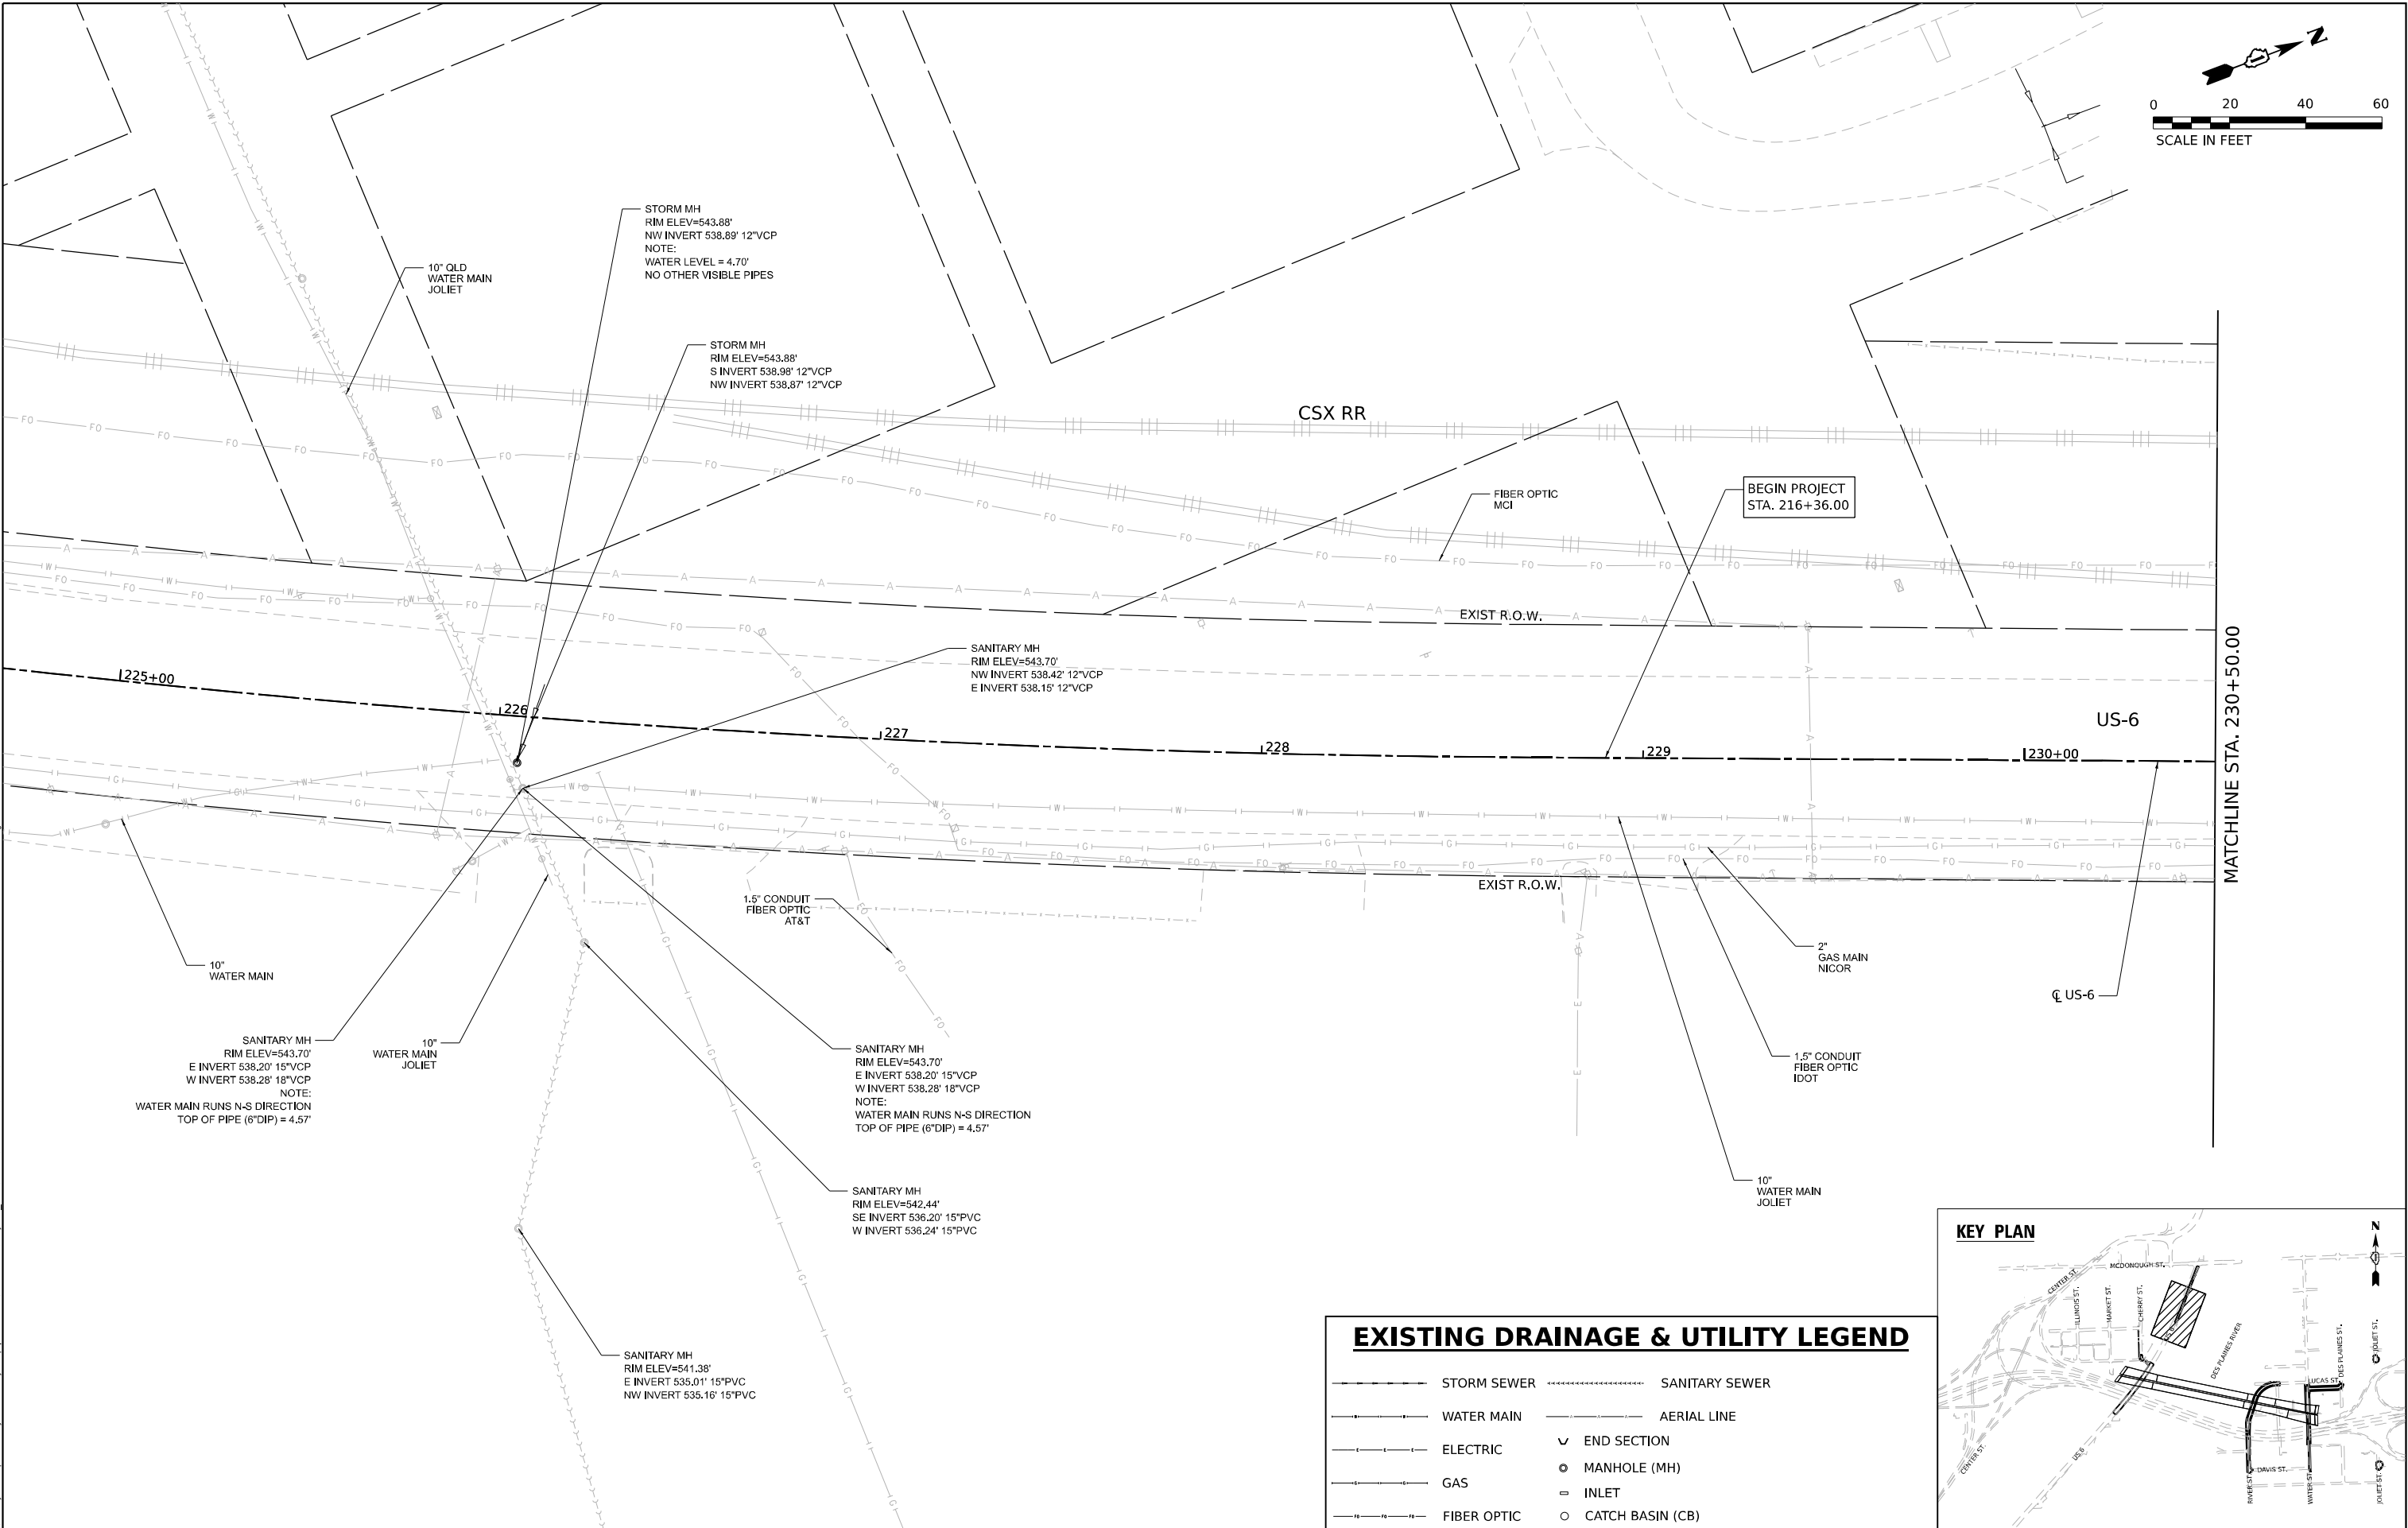


EXISTING DRAINAGE & UTILITY LEGEND

- | | | | |
|--|-------------|--|------------------|
| | STORM SEWER | | SANITARY SEWER |
| | WATER MAIN | | AERIAL LINE |
| | ELECTRIC | | END SECTION |
| | GAS | | MANHOLE (MH) |
| | FIBER OPTIC | | INLET |
| | | | CATCH BASIN (CB) |

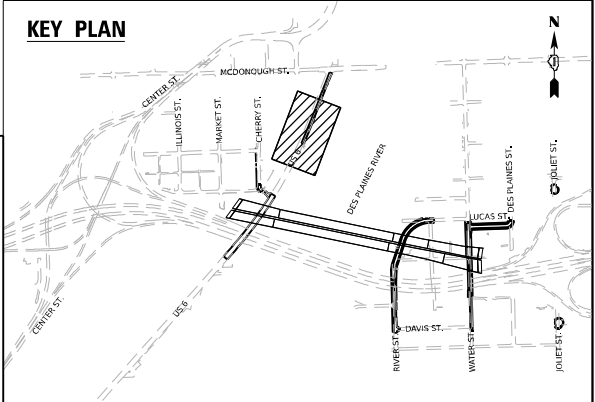

	WSP USA INC. 30 N. LASALLE STREET SUITE 4200 CHICAGO, IL 60602 TEL: (312) 782-8150	USER NAME = USHC706648	DESIGNED - SSM	REVISED -	STATE OF ILLINOIS DEPARTMENT OF TRANSPORTATION	EXISTING DRAINAGE AND UTILITY PLANS			F.A.I. RTE.	SECTION	COUNTY	TOTAL SHEETS	SHEET NO.
		PLOT SCALE = 40,000' / in.	DRAWN - CC	REVISED -		US-6			80	FAI 80 21 STRUCTURE 2	WILL	1230	327
		PLOT DATE = 11/6/2025	CHECKED - HC	REVISED -		SCALE: 1"=20'			CONTRACT NO. 62R23				
			DATE - 11/7/2025	REVISED -		SHEET 3 OF 12 SHEETS	STA.	TO STA.	ILLINOIS FED. AID PROJECT				

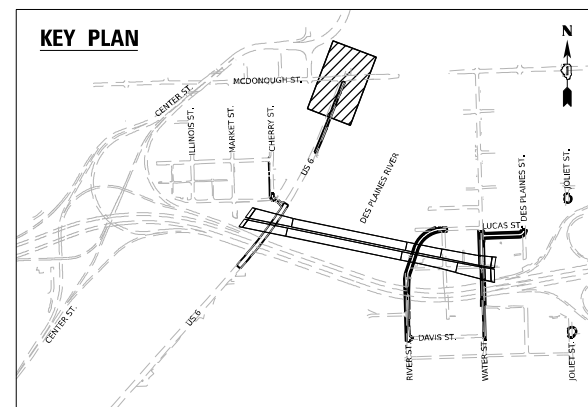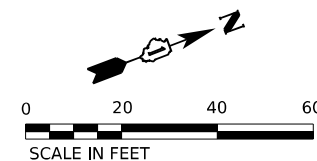

EXISTING DRAINAGE & UTILITY LEGEND

	STORM SEWER		SANITARY SEWER
	WATER MAIN		AERIAL LINE
	ELECTRIC	✓	END SECTION
	GAS	⊙	MANHOLE (MH)
	FIBER OPTIC	⊞	INLET
		○	CATCH BASIN (CB)


EAST PIPE COULD NOT BE MEASURED WITH CERTAINTY
BECAUSE OFFSET DISTANCE FROM THE CENTER OF MH
IS FAR OUT BUT IT IS ESTIMATED TO BE GREATER THAN
36" IN SIZE


STATE OF ILLINOIS
DEPARTMENT OF TRANSPORTATION


EXISTING DRAINAGE AND UTILITY PLANS
US-6

SCALE: 1"=20'	SHEET 4 OF 12 SHEETS	STA.	TO STA.
---------------	----------------------	------	---------


F.A.I. RTE.	SECTION	COUNTY	TOTAL SHEETS	SHEET NO.
80	FAI 80 21 STRUCTURE 2	WILL	1230	328
		CONTRACT NO. 62R23		
ILLINOIS		FED. AID PROJECT		

 

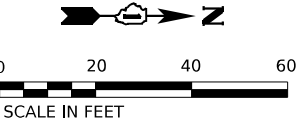wsp

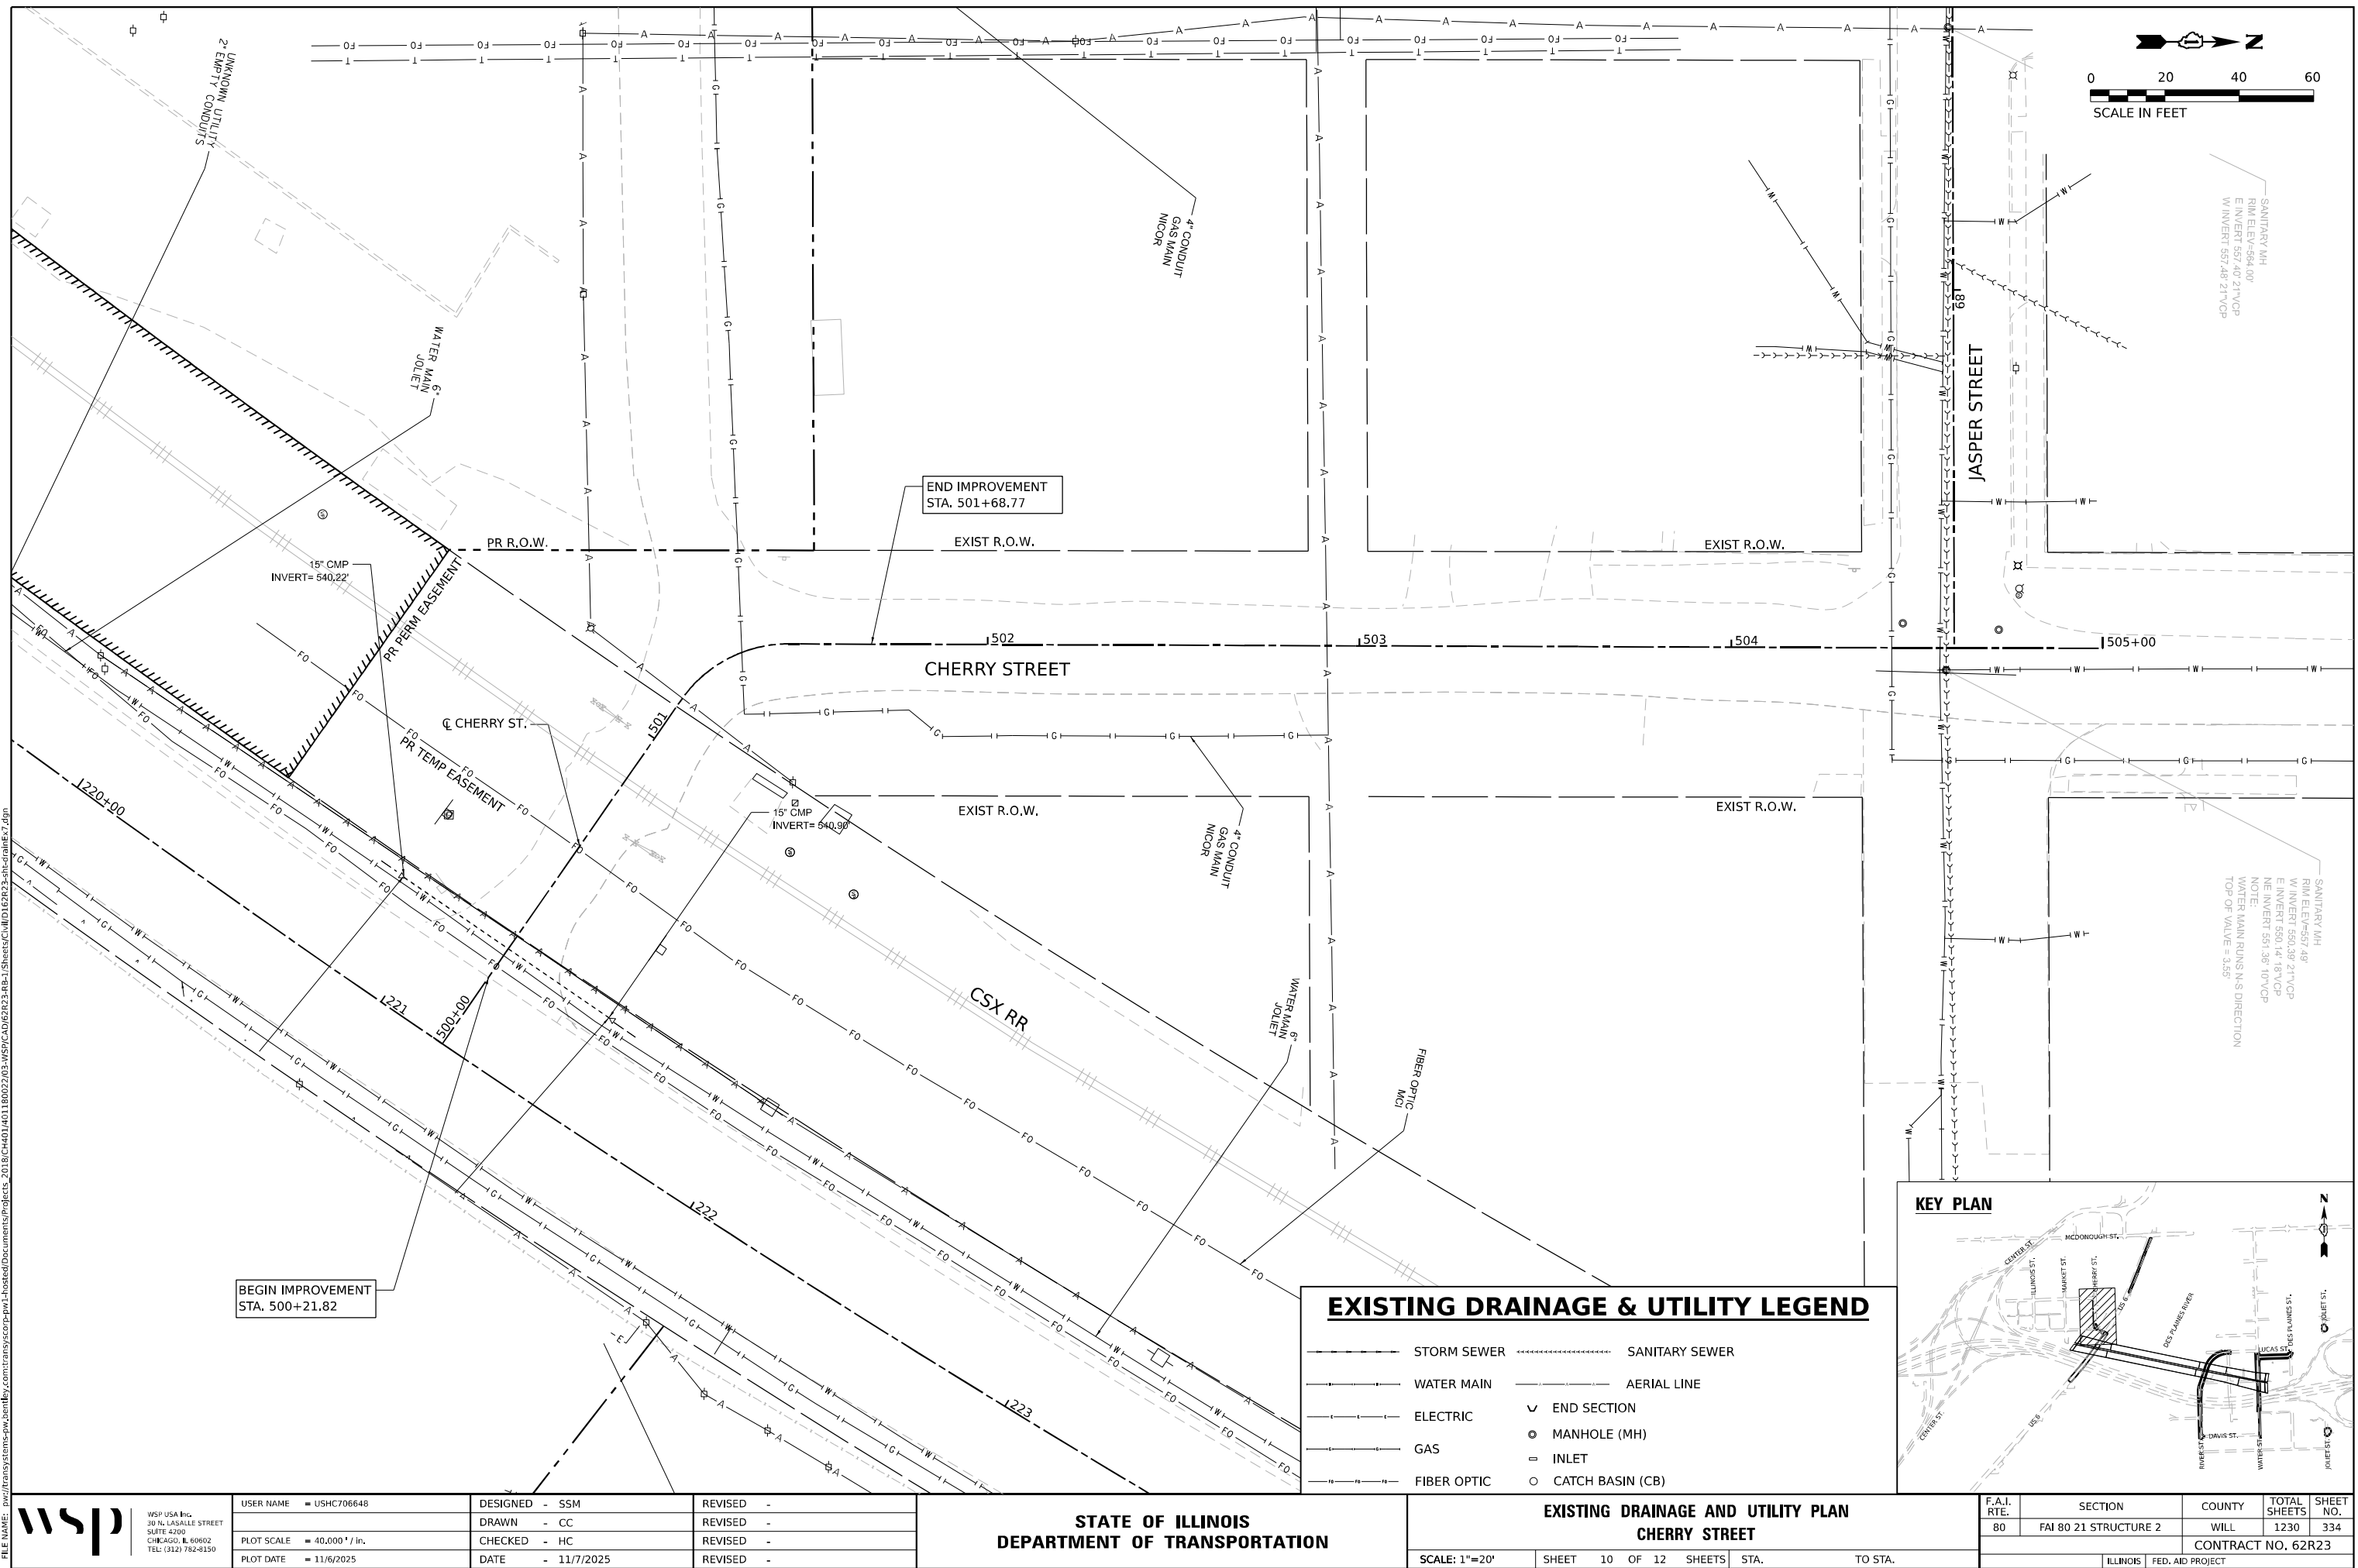


Model: Default
File Name: p:\projects\trans\trans-stone-pw-bentley.com\trans\corp-pw-limited\Documents\projects_2018\CH4001401180022\03-WSP\CD\62R23-RB-1-Sheets\CD\62R23-shr-dpaine.s.dgn

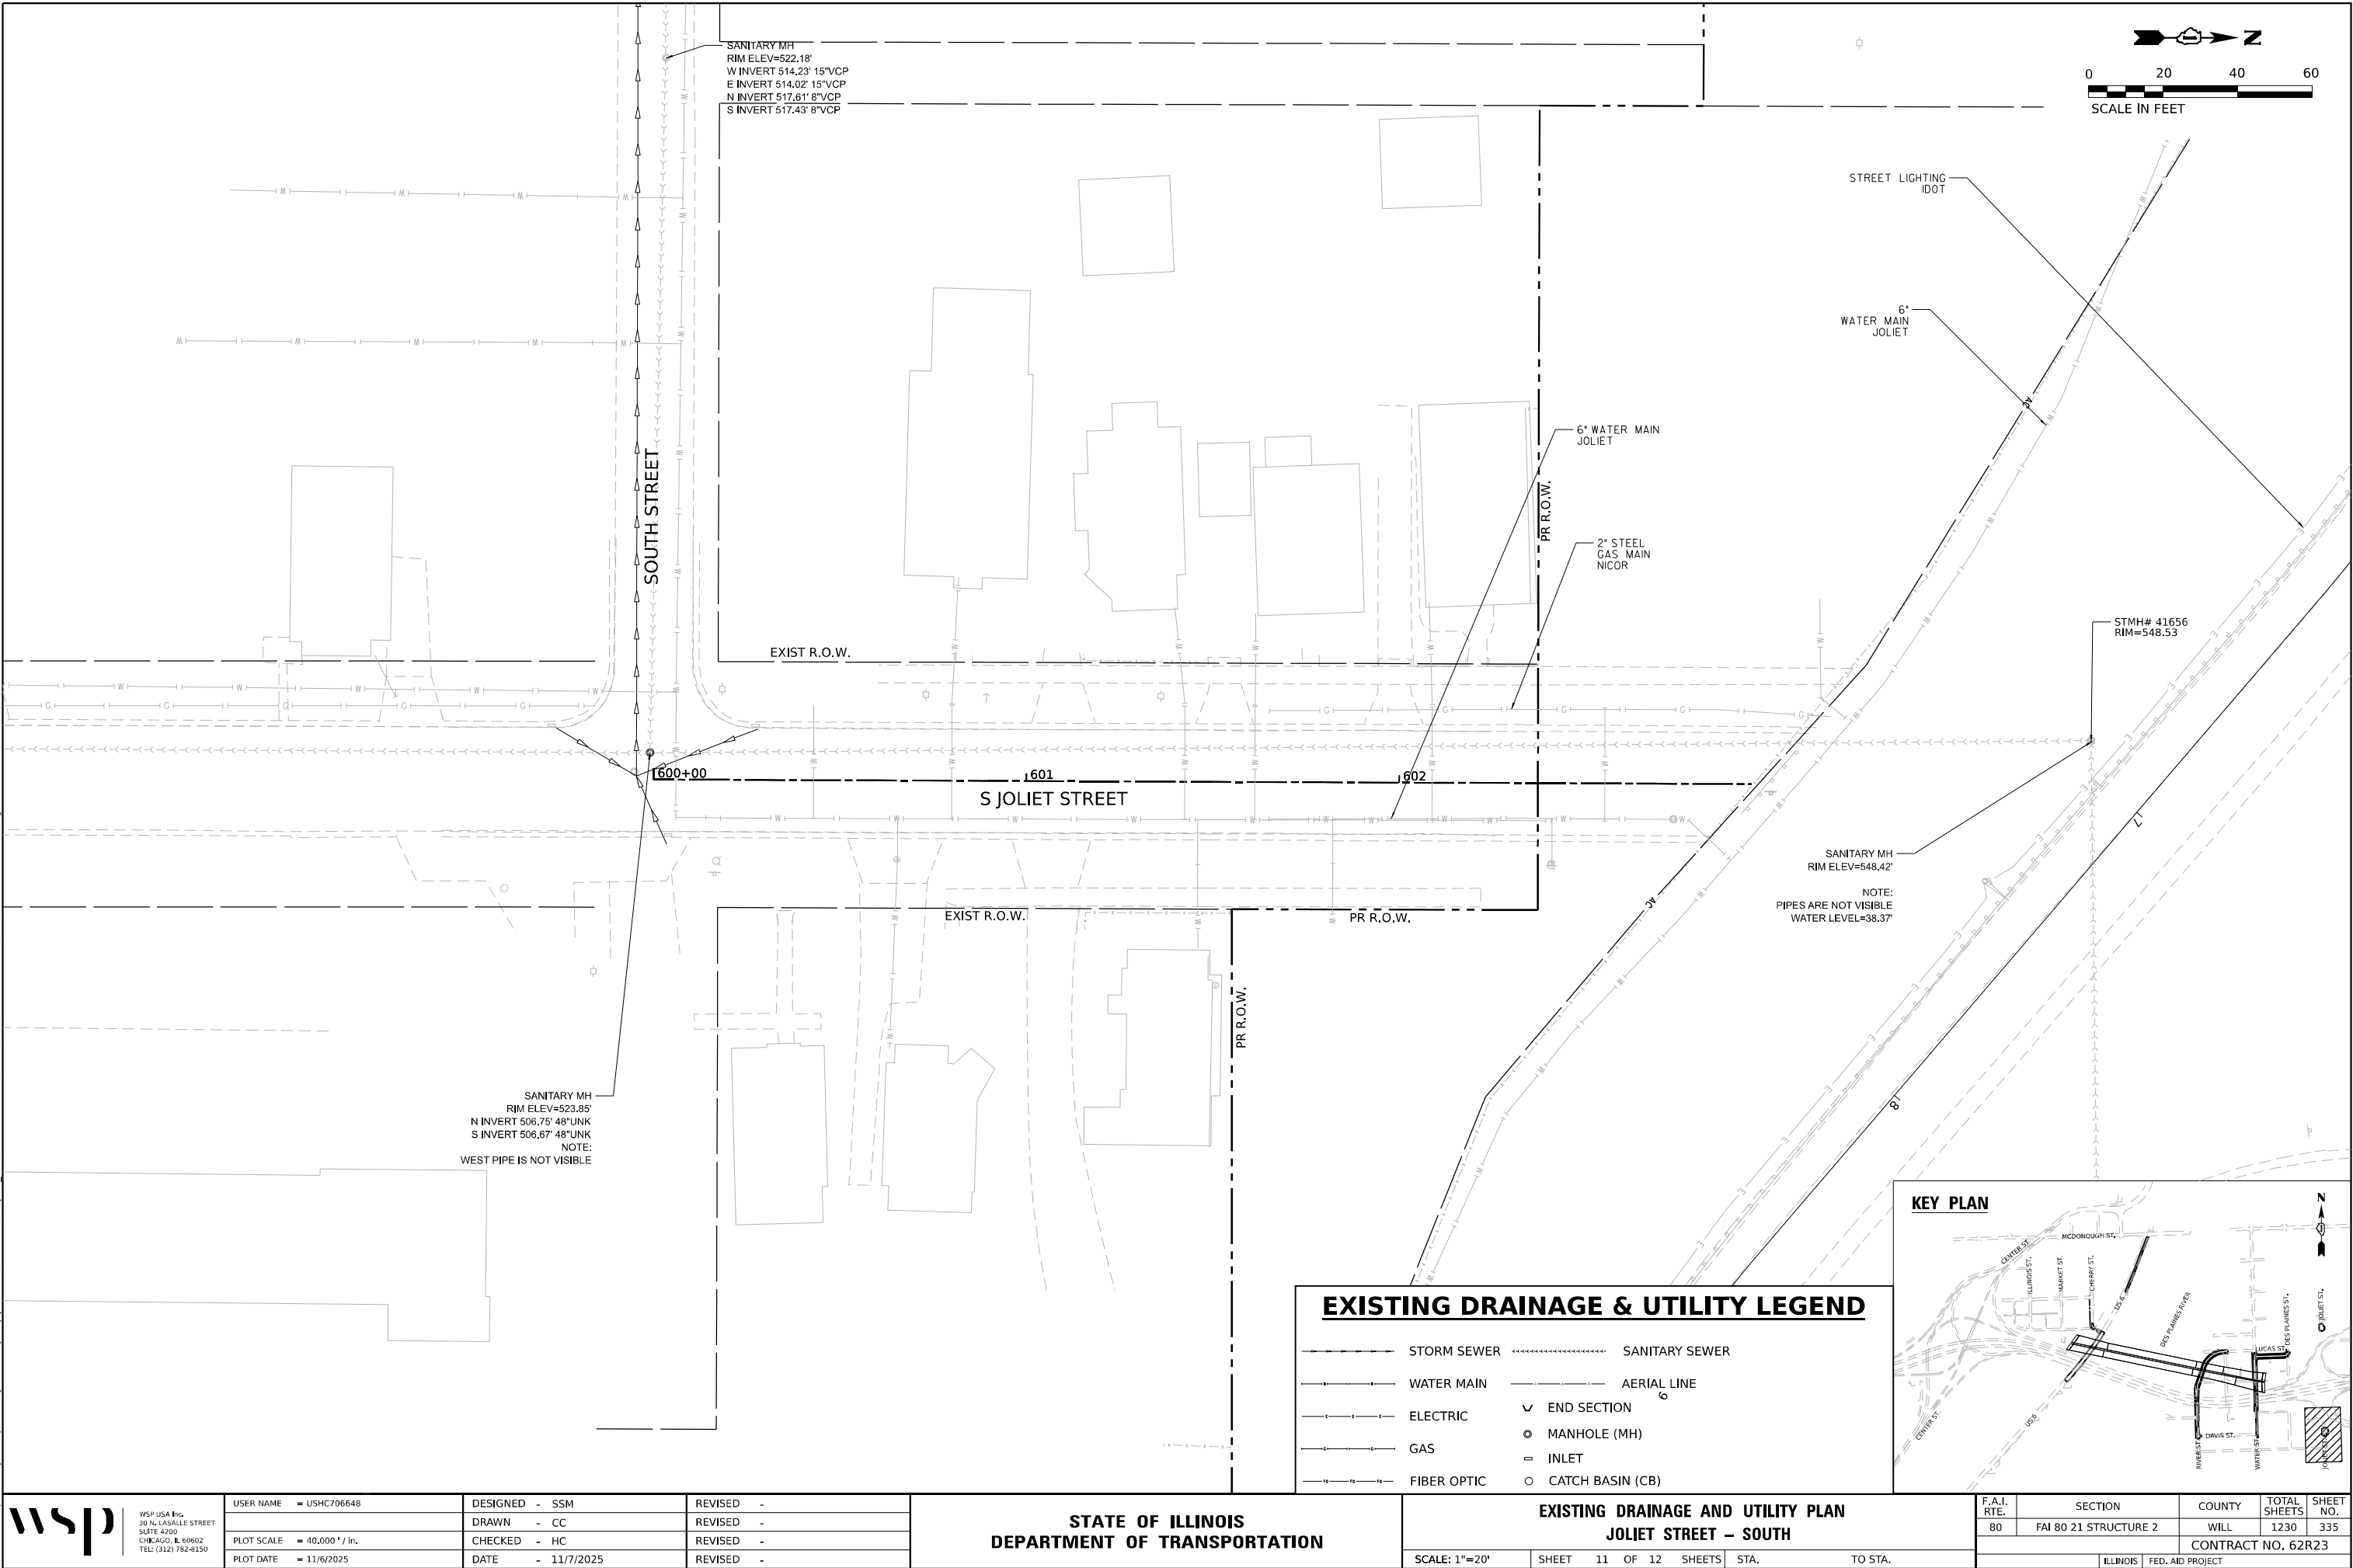


EXISTING DRAINAGE & UTILITY LEGEND

- | | |
|-------------|------------------|
| STORM SEWER | SANITARY SEWER |
| WATER MAIN | AERIAL LINE |
| ELECTRIC | END SECTION |
| GAS | MANHOLE (MH) |
| FIBER OPTIC | INLET |
| | CATCH BASIN (CB) |

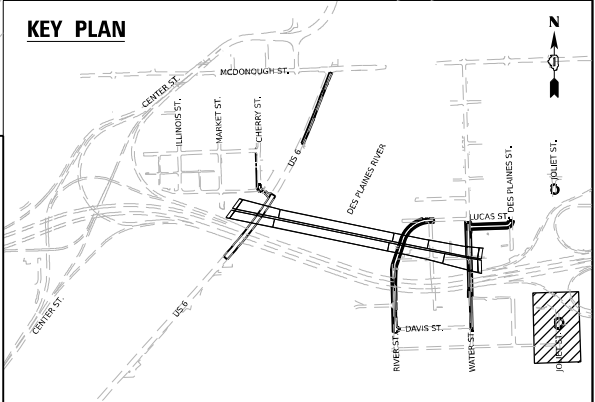


 WSP USA INC. 30 N. LA SALLE STREET SUITE 4200 CHICAGO, IL 60602 TEL: (312) 782-8150	USER NAME = USHC706648		DESIGNED - SSM	REVISED -	STATE OF ILLINOIS DEPARTMENT OF TRANSPORTATION	EXISTING DRAINAGE AND UTILITY PLAN JOLIET STREET – SOUTH				F.A.I. RTE.	SECTION	COUNTY	TOTAL SHEETS	SHEET NO.
	PLOT SCALE = 40,000' / in.		DRAWN - CC	REVISED -		80	FAI 80 21 STRUCTURE 2	WILL	1230	335				
	PLOT DATE = 11/6/2025		CHECKED - HC	REVISED -		CONTRACT NO. 62R23								
	PLOT DATE = 11/7/2025		DATE - 11/7/2025	REVISED -										
						SCALE: 1"=20'	SHEET 11 OF 12 SHEETS	STA.		TO STA.				

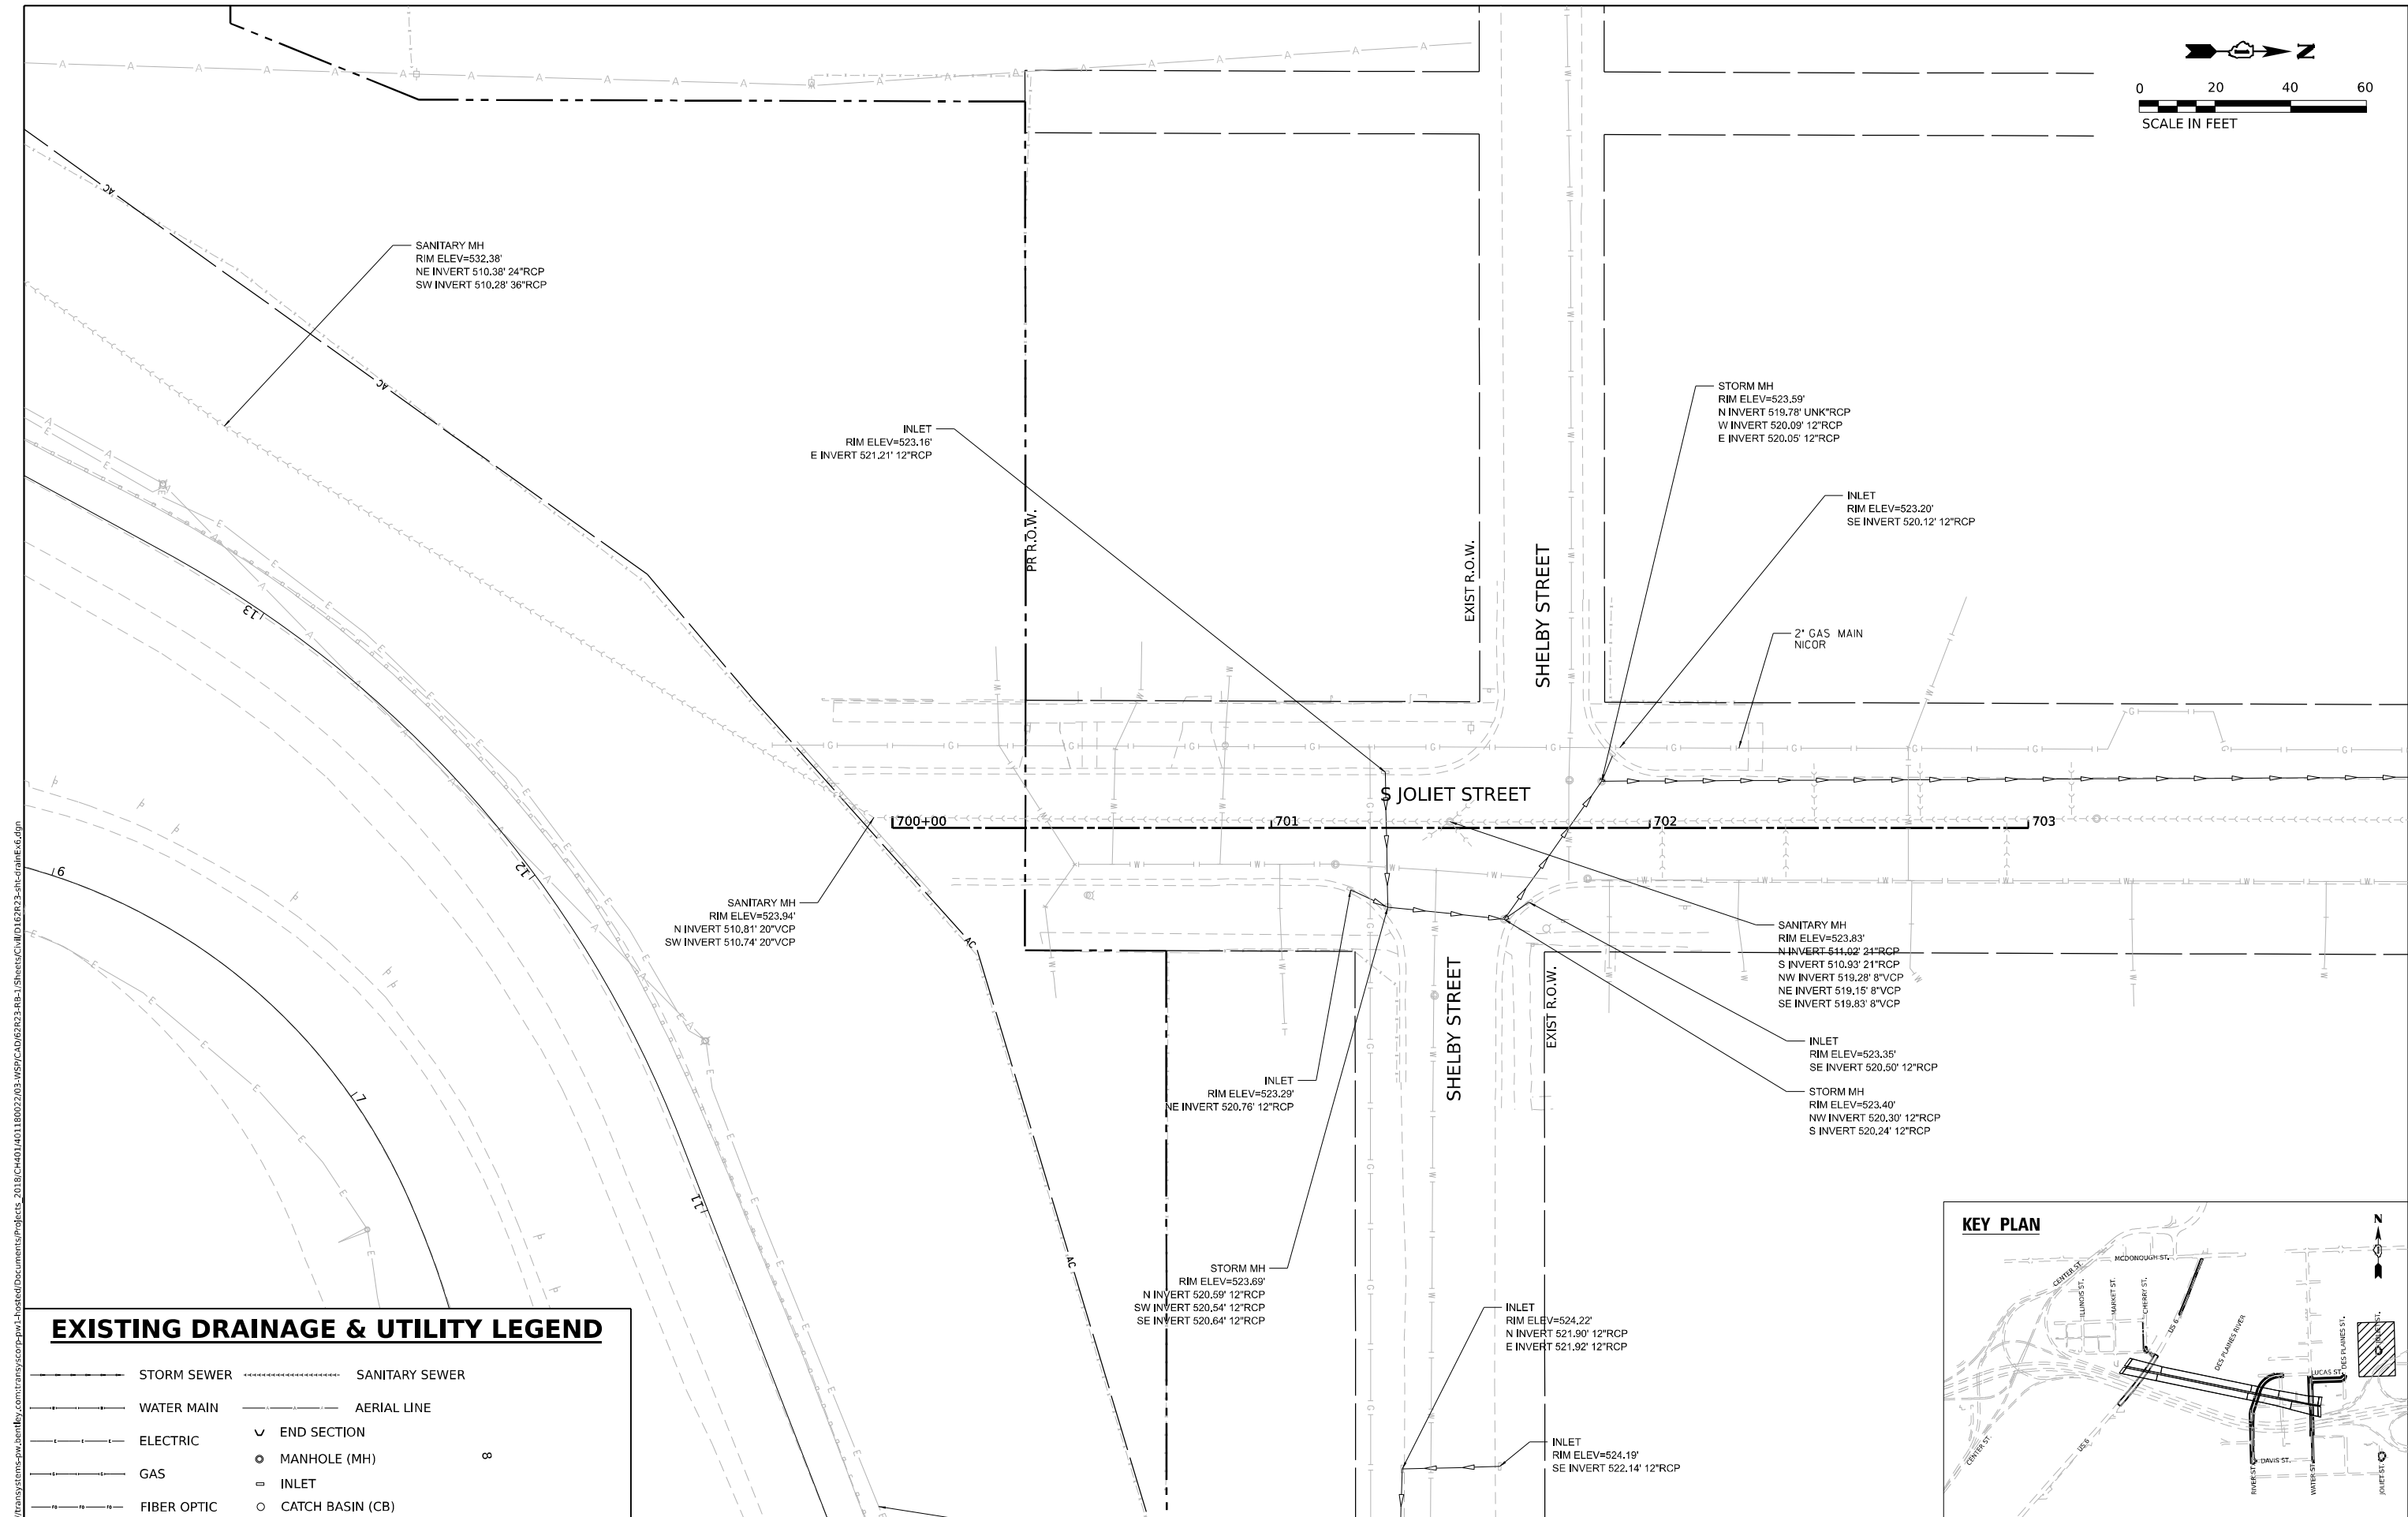


	STORM SEWER		SANITARY SEWER
	WATER MAIN		AERIAL LINE
	ELECTRIC		END SECTION
	GAS		MANHOLE (MH)
	FIBER OPTIC		INLET
			CATCH BASIN (CB)

STATE OF ILLINOIS
DEPARTMENT OF TRANSPORTATION

F.A.I. RTE.	SECTION	COUNTY	TOTAL SHEETS	SHEET NO.
80	FAI 80 21 STRUCTURE 2	WILL	1230	336
		CONTRACT NO. 62R23		
ILLINOIS		FED. AID PROJECT		

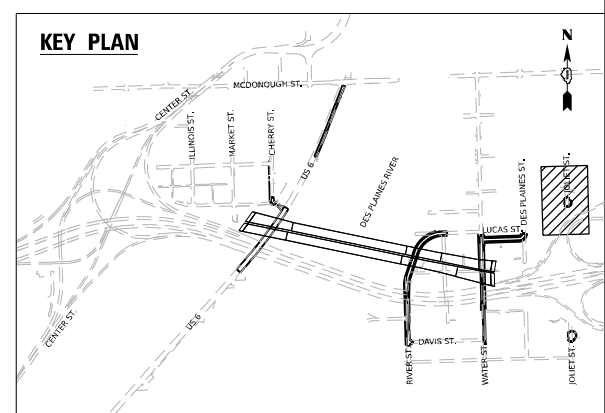

MODEL: Default: c:\projects\trans\stone-pw-bentley.com\trans\corp-pw-labeled\Documents\Projects_2018\CH4001401180022\03-WSP\CH4001401180022-03-eh-drainplan1.dgn
FILE NAME: c:\projects\trans\stone-pw-bentley.com\trans\corp-pw-labeled\Documents\Projects_2018\CH4001401180022\03-WSP\CH4001401180022-03-eh-drainplan1.dgn

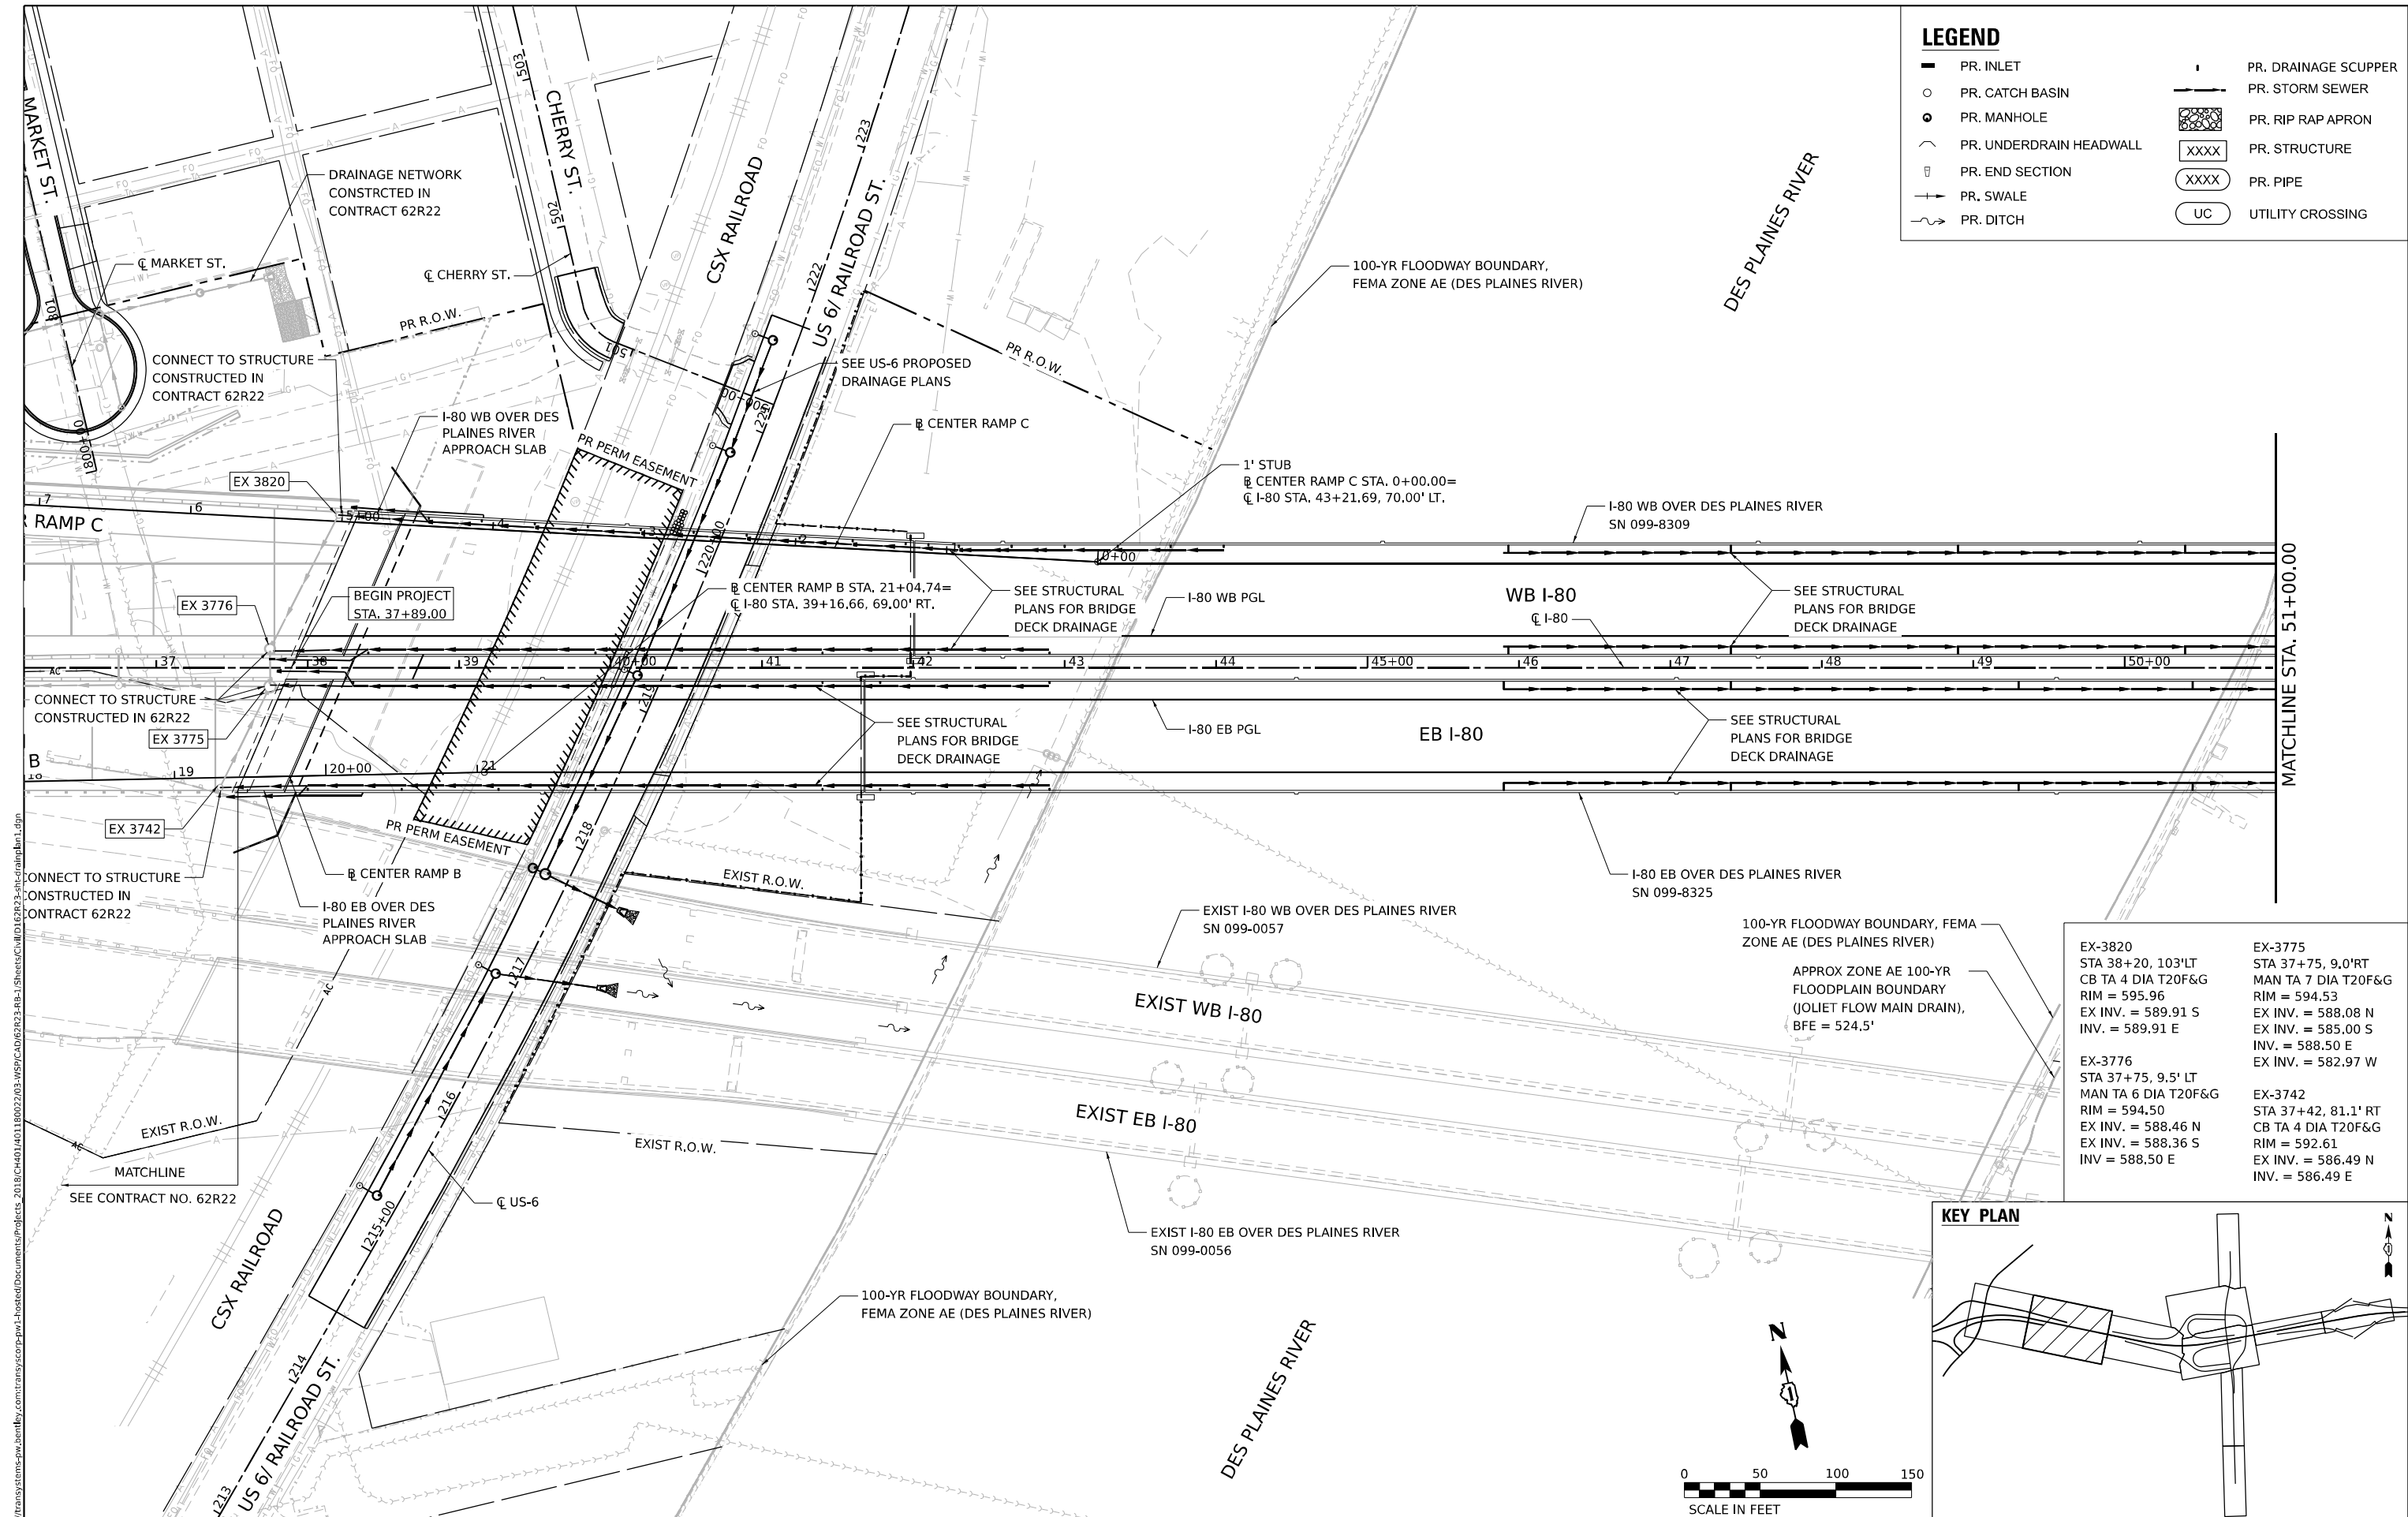

LEGEND

PR. INLET

PR. CATCH BASIN

PR. MANHOLE

PR. UNDERDRAIN HEADWALL

PR. END SECTION

PR. SWALE

PR. DITCH

PR. DRAINAGE SCUPPER

PR. STORM SEWER

PR. RIP RAP APRON

PR. STRUCTURE

PR. PIPE

UTILITY CROSSING

EX-3820
STA 38+20, 103'LT
CB TA 4 DIA T20F&G
RIM = 595.96
EX INV. = 589.91 S
INV. = 589.91 E

EX-3775
STA 37+75, 9.0'RT
MAN TA 7 DIA T20F&G
RIM = 594.53
EX INV. = 588.08 N
EX INV. = 585.00 S
INV. = 588.50 E
EX INV. = 582.97 W

EX-3776
STA 37+75, 9.5' LT
MAN TA 6 DIA T20F&G
RIM = 594.50
EX INV. = 588.46 N
EX INV. = 588.36 S
INV. = 588.50 E

EX-3742
STA 37+42, 81.1' RT
CB TA 4 DIA T20F&G
RIM = 592.61
EX INV. = 586.49 N
INV. = 586.49 E

WSP

WSP USA Inc.
30 N. LA SALLE STREET
SUITE 4200
CHICAGO, IL 60602
TEL: (312) 782-8150

USER NAME = USHC706648

AKG

SSM

KS

PLOT SCALE = 100,000' / in.

PLOT DATE = 11/6/2025

DESIGNED - DB

DRAWN - HC

CHECKED - KS

DATE - 11/7/2025

REVISED -

REVISED -

REVISED -

REVISED -

STATE OF ILLINOIS

DEPARTMENT OF TRANSPORTATION

PROPOSED DRAINAGE AND UTILITY PLAN

I-80

SCALE: 1" = 50'

SHEET 1 OF 4 SHEETS

STA. TO STA.

F.A.I. RTE.	SECTION	COUNTY	TOTAL SHEETS	SHEET NO.
80	FAI 80 21 STRUCTURE 2	WILL	1230	337
CONTRACT NO. 62R23				
ILLINOIS FED. AID PROJECT				

LEGEND

- PR. INLET

PR. CATCH BASIN

PR. UNDERDRAIN HEADWALL

PR. END SECTION

PR. DRAINAGE SCUPPER

PR. SWALE

PR. MANHOLE

PR. STORM SEWER

PR. PIPE UNDERDRAIN

PR. RIP RAP APRON

XXXX

PR. STRUCTURE

XXXX

PR. PIPE

PR. DITCH

UC

UTILITY CROSSING
- NOTES:

1. FOR PIPE UNDERDRAIN DETAILS AND SCHEDULE, SEE SHEET 385

2. FOR PLACEMENT OF DRAINAGE STRUCTURE, SEE SHEET 383

3. FOR RIPRAP DETAILS, SEE SHEET 384

4. UC: PROPOSED STORM SEWER CROSSING OVER PROPOSED CITY OF JOLIET UTILITIES; REFER TO JOLIET DRAINAGE AND UTILITY PLANS

MODEL Default: FILE NAME: p:\proj\trans\trans\w\hantley.com\trans\corp\proj\hatched\Documents\Projects_2018\CH4001\401180022\03-WSP\CD\62R23-RB-1\Sheet\CL\110162R23-shd.drainplan2.dgn

NOTE:
* FLAT SLAB TOP

DS-1300 STA 113+02, 120'RT CB TA 4 DIA T8G RIM = 522.04 INV. = 518.45 W	DS-1651 STA 116+50, 10.8'RT CB TA 4 DIA T20F&G RIM = 559.27 INV. = 552.30 N INV. = 552.20 E	DS-6016 STA 60+14, 103.5'LT CB TA 5 DIA T20F&G RIM = 562.84 INV. = 555.50 S INV. = 566.50 W	IDS-1337 STA 113+37, 83.8'LT MAN TA 4 DIA T8G RIM = 549.85 INV. = 545.89 NW INV. = 545.79 SE	*IDS-6013 STA 60+13, 4.5'LT MAN TA 5 DIA T8G RIM = 565.20 INV. = 554.75 N INV. = 550.24 E INV. = 554.68 S	SS-1300 STORM SEW CL A 2 15 129' @ 0.35% TBF = 0.0 CY	SS-6035 STORM SEW CL A 2 24 108' @ 1.00% TBF = 83.4 CY	ISS-5086 P CUL CL A 1 12 6' @ 0.50% TBF = 0.0 CY	ISS-6302 P CUL CL A 2 36 TEMP 95' @ 0.84% TBF = 95.0 CY
DS-1350 STA 113+50, 13'RT MAN TA 4 DIA T20F&G RIM = 554.32 INV. = 548.50 W INV. = 547.16 S	DS-1800 STA 118+00, 145'RT CB TA 5 DIA T8G RIM = 521.50 INV. = 517.00 E INV. = 516.90 W INV. = 516.94 N	DS-6035 STA 60+31, 118.2'RT CB TA 5 DIA T20F&G RIM = 567.47 INV. = 560.90 N INV. = 561.40 W	IDS-5082 STA 508+16, 30.5'RT CB TA 4 DIA T8G RIM = 559.58 INV. = 550.30 N INV. = 550.20 S	*IDS-6204 STA 62+00, 4.0'LT CB TA 5 DIA T8G RIM = 558.66 INV. = 551.46 N INV. = 548.71 W, E	SS-1450 STORM SEW CL A 2 15 93' @ 1.62% TBF = 13.8 CY	SS-6070 STORM SEW CL A 2 15 113' @ 1.70% TBF = 70.3 CY	ISS-5087 STORM SEW MN REQ 12 51' @ 0.50% TBF = 1.3 CY	ISS-6402 P CUL CL A 2 36 TEMP 70' @ 0.86% TBF = 22.3 CY
DS-1450 STA 114+50, 13'RT CB TA 4 DIA T20F&G RIM = 555.50 INV. = 550.00 E INV. = 550.10 W	*DS-1900 STA 119+12, 138'RT MAN TA 4 DIA T1F CL RIM = 520.95 INV. = 516.07 E EX INV. = 516.07' N	DS-6070 STA 607+00, 22.0'RT CB TA 4 DIA T20F&G RIM = 563.71 INV. = 555.50 S INV. = 555.40 E	*IDS-5083 STA 508+19, 55.0'RT MAN TA 4 DIA T8G RIM = 552.70 INV. = 550.00 N INV. = 546.75 S	IDS-6205 STA 62+00, 9.5'LT CB TA 4 DIA T8G RIM = 556.40 INV. = 551.50 E	SS-1500 STORM SEW CL A 2 15 246' @ 0.40% TBF = 0.0 CY	SS-6071 STORM SEW CL A 2 15 5' @ 1.00% TBF = 0.4 CY	ISS-6002 P CUL CL A 2 24 TEMP 3' @ 2.0% TBF = 5.0 CY	ISS-6474 P CUL CL A 1 36 TEMP 45' @ 0.87% TBF = 39.1 CY
DS-1500 STA 115+00, 122.5'RT CB TA 4 DIA T8G RIM = 523.67 INV. = 518.00 E INV. = 517.90 W	DS-6000 STA 60+13, 2.3'RT MAN TA 8 DIA T20F&G RIM = 568.57 INV. = 554.70 N INV. = 559.83 S INV. = 559.50 W	DS-6071 STA 607+00, 29.0'RT CB TA 4 DIA T1F OL RIM = 563.42 INV. = 555.55 N	IDS-5085 STA 508+49, 122.2'RT METAL FL END SEC 18" INV. = 520.50	*IDS-6302 STA 63+00, 4.0'LT CB TA 5 DIA T8G RIM = 554.20 INV. = 546.91 E INV. = 547.91 W	SS-1650 STORM SEW CL A 2 15 4' @ 2.89% TBF = 0.7 CY	ISS-1337 STORM SEW CL A 2 15 54' @ 3.30% TBF = 0.0 CY	ISS-6003 P CUL CL A 2 24 TEMP 2' @ 1.00% TBF = 4.4 CY	
DS-1550 STA 115+50, 13'RT CB TA 4 DIA T20F&G RIM = 556.77 INV. = 551.60 W INV. = 551.50 E	DS-6001 STA 60+13, 10'LT CB TA 5 DIA T20F&G (WITH 48" SUMP) RIM = 563.75 INV. = 554.91 N INV. = 554.81 S INV. = 551.27 S (24" TD-P3.1) INV. = 559.22 W	DS-6081 STA 608+16, 24.1'RT CB TA 4 DIA T20F&G RIM = 560.16 INV. = 553.50 W INV. = 550.34 S	IDS-5086 STA 508+70, 119'RT PRC FLAR END SEC 12 INV. = 520.30	*IDS-6401 STA 64+00, 4.5'LT CB TA 5 DIA T8G RIM = 551.50 INV. = 543.91 E INV. = 546.11 W	SS-1651 STORM SEW CL A 2 15 95' @ 0.64% TBF = 31 CY	ISS-5081 STORM SEW CL A 2 15 7' @ 0.63% TBF = 0.0 CY	ISS-6204 P CUL CL A 2 36 TEMP 95' @ 0.84% TBF = 136.7 CY	
DS-1650 STA 116+50, 16.4'RT CB TA 4 DIA T1F OL RIM = 559.19 INV. = 552.40 S		IDS-1330 STA 113+37, 83.8'LT PRC FLAR END SEC 15 INV. = 544.00 SE	IDS-5087 STA 508+93, 124.0'RT MH TA 6D W/2 T1FCL RP RIM = 524.00 INV. = 520.26 N, S	*IDS-6474 STA 64+75, 4.5'LT CB TA 5 DIA T8G RIM = 549.30 INV. = 543.21 E INV. = 543.31 W	SS-1800 STORM SEW CL A 2 15 98' @ 0.85% TBF = 0.0 CY	ISS-5082 STORM SEW CL A 2 15 21' @ 0.97% TBF = 0.0 CY	ISS-6205 P CUL CL A 2 12 TEMP 1' @ 4.00% TBF = 3.0 CY	
					SS-6016 STORM SEW CL A 3 24 85' @ 0.70% TBF = 73.2 CY	ISS-5083 PIPE DRAINS 18 65' @ 40.0% TBF = 0.0 CY		



WSP USA INC.
30 N. LASALLE STREET
SUITE 4200
CHICAGO, IL 60602
TEL: (312) 782-8159

USER NAME = USHC706648	DESIGNED - DB	REVISED -
	DRAWN - HC	REVISED -
PLOT SCALE = 100,000' / in.	CHECKED - KS	REVISED -
PLOT DATE = 11/6/2025	DATE - 11/7/2025	REVISED -

STATE OF ILLINOIS
DEPARTMENT OF TRANSPORTATION

PROPOSED DRAINAGE AND UTILITY PLAN
I-80

SCALE: 1" = 50' SHEET 2 OF 4 SHEETS STA. TO STA.

F.A.I. RTE.	SECTION	COUNTY	TOTAL SHEETS	SHEET NO.
80	FAI 80 21 STRUCTURE 2	WILL	1230	338
CONTRACT NO. 62R23				
ILLINOIS FED. AID PROJECT				

KEY PLAN

LEGEND

- PR. INLET

PR. CATCH BASIN

PR. MANHOLE

PR. UNDERDRAIN HEADWALL

PR. END SECTION

PR. SWALE

PR. STORM SEWER

PR. PIPE UNDERDRAIN

PR. RIP RAP APRON

XXXX

PR. STRUCTURE

XXXX

PR. PIPE

PR. DITCH
- PR. R.O.W.
- EXIST R.O.W.

NOTES:

1. FOR PIPE UNDERDRAIN DETAILS AND SCHEDULE, SEE SHEET 385
2. FOR PLACEMENT OF DRAINAGE STRUCTURE, SEE SHEET 383
3. FOR RIPRAP DETAILS, SEE SHEET 384

IDS-1074
STA 107+44, 50.1'LT
CB TA 5 DIA T8G
RIM = 540.00
INV. = 526.29 S

MODEL: Default
FILE NAME: p:\projects\trans\scorp\ppl\hatched\Documents\projects_2018\CH401\401180022\03-WSP\CH401\02R23-RB-1_Sheets\CH401\02R23-shd-drainage2b.dgn



WSP USA INC.
30 N. LA SALLE STREET
SUITE 4200
CHICAGO, IL 60602
TEL: (312) 782-8150

USER NAME	= USHC706648
DESIGNED	- AKG
DRAWN	- SSM
CHECKED	- KS
DATE	- 11/7/2025
PLOT SCALE	= 100,000' / in.
PLOT DATE	= 11/6/2025

DESIGNED	- AKG
DRAWN	- SSM
CHECKED	- KS
DATE	- 11/7/2025

REVISED	-
REVISED	-
REVISED	-
REVISED	-

STATE OF ILLINOIS
DEPARTMENT OF TRANSPORTATION

PROPOSED DRAINAGE AND UTILITY PLAN
I-80

SCALE: 1" = 50' SHEET 4 OF 4 SHEETS STA. TO STA.

F.A.I. RTE.	SECTION	COUNTY	TOTAL SHEETS	SHEET NO.
80	FAI 80 21 STRUCTURE 2	WILL	1230	340
CONTRACT NO. 62R23				
ILLINOIS FED. AID PROJECT				

PROFILE			BY	DATE
	SURVEYED			
	PLOTTED			
NOTE BOOK	GRADES CHECKED			
	R.M. NOTED			
NO. _____	STRUCTURE NOTATIONS CHK'D			

WSP | WSP USA Inc.
30 N. LASALLE STREET
SUITE 4200
CHICAGO, IL 60602
TEL: (312) 782-8150


STATE OF ILLINOIS
DEPARTMENT OF TRANSPORTATION

F.A.I. RTE.	SECTION	COUNTY	TOTAL SHEETS	SHEET NO.
80	FAI 80 21 STRUCTURE 2	WILL	1230	342
		CONTRACT NO. 62R23		
ILLINOIS		FED. AID PROJECT		

PLAN	SURVEYED PLOTTED ALIGNMENT CHECKED BY CADD FILE NAME	BY	DATE
NOTE BOOK NO.			

PROFILE	SURVEYED PLOTTED GRADES CHECKED BY STRUCTURE NOTATION CHKO	BY	DATE
NOTE BOOK NO.			

MODEL: I80-DRNCD_Profile1 - Profile 2 [Sheet]
FILE NAME: p:\projects\transystemspw\jeniley.com\transyscorp-pw\shared\Documents\Projects\2018\CH401\401180022\03-WSP\CAD\62R23-rb-1-Sheets\Civil\I80-23-shr-drain\Profile-I80.dgn

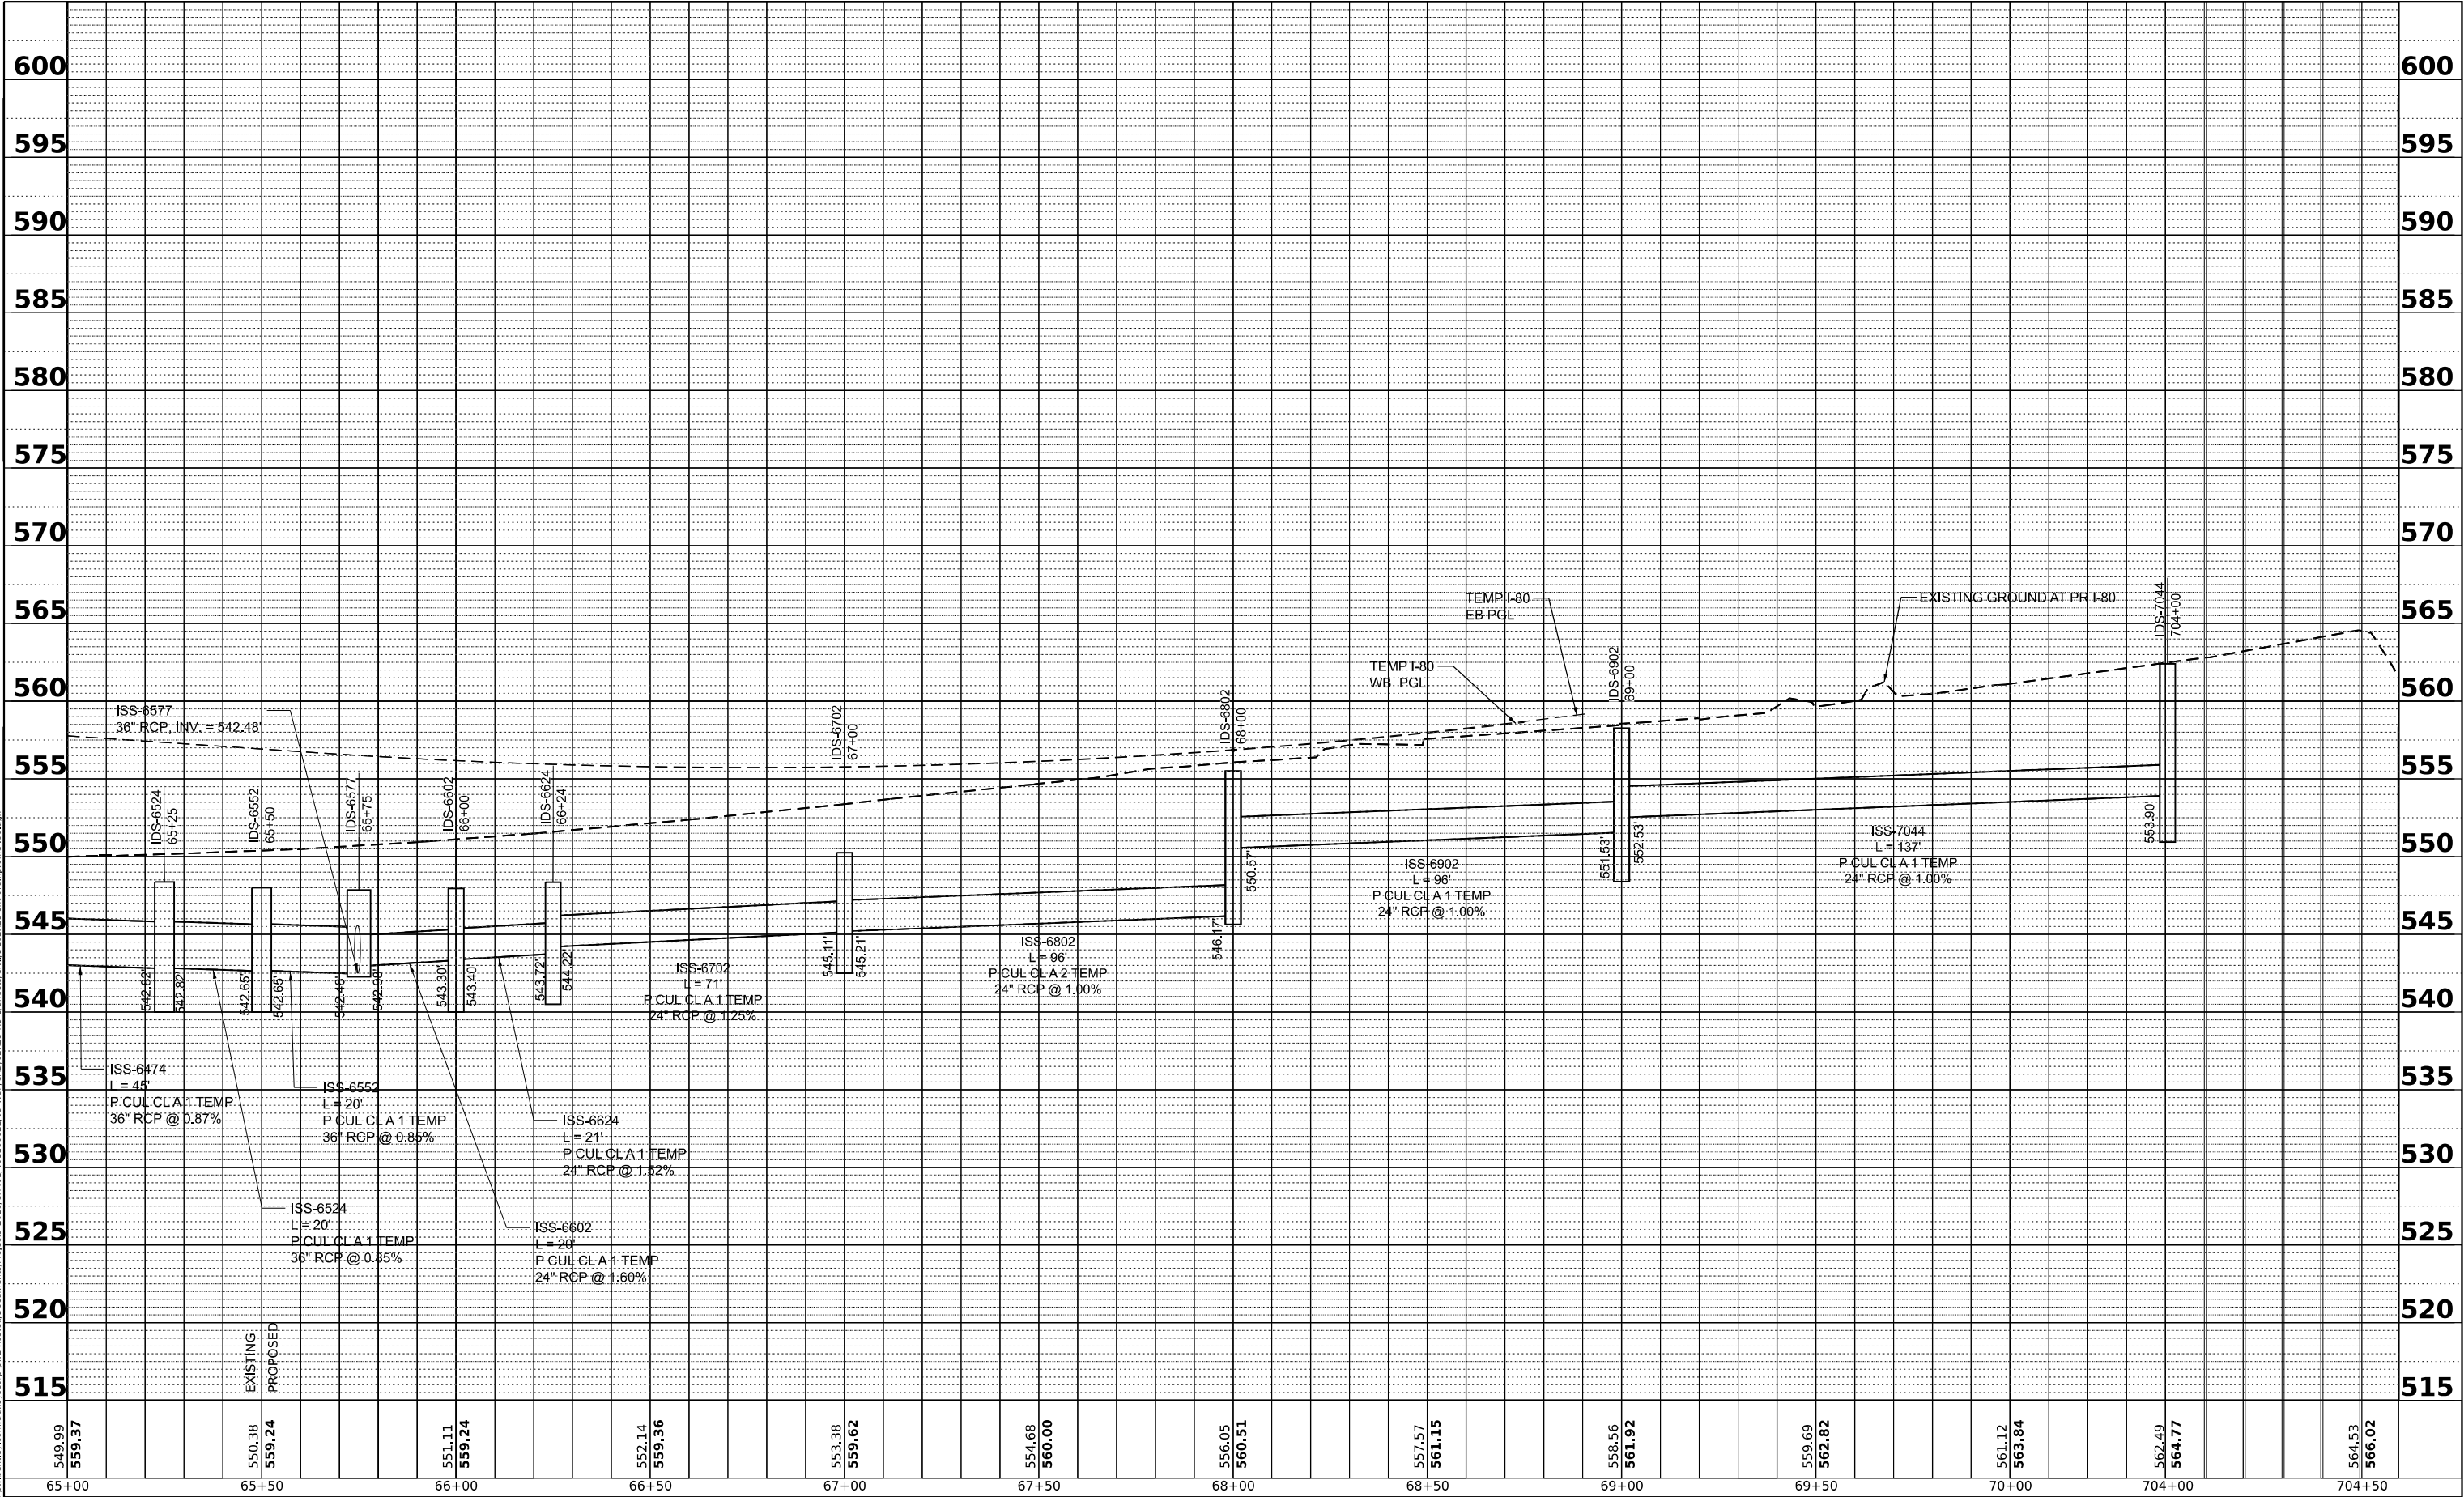


 WSP USA Inc. 30 N. LASALLE STREET SUITE 4200 CHICAGO, IL 60602 TEL: (312) 782-8150		USER NAME = USHC706648		DESIGNED - DB		REVISED -		STATE OF ILLINOIS DEPARTMENT OF TRANSPORTATION										PROPOSED DRAINAGE AND UTILITY PROFILE I-80				F.A.I. RTE.	SECTION		COUNTY	TOTAL SHEETS	SHEET NO.				
		PLOT SCALE = 0.16666667' / in.		DRAWN - HC		REVISED -												80	FAI 80 21 STRUCTURE 2		WILL	1230	343								
		PLOT DATE = 11/6/2025		CHECKED - KS		REVISED -												SCALE: HORIZ: 1"=50' VERT: 1"=5'				SHEET 2	OF 2	SHEETS	STA.	TO STA.			CONTRACT NO. 62R23		
		DATE - 11/7/2025		REVISED -															ILLINOIS	FED. AID PROJECT											

PLAN		BY		DATE
NOTE BOOK NO. _____	SURVEYED _____			
	PLOTTED _____			
	ALIGNMENT CHECKED _____			
	RT. OF WAY CHECKED _____			
CADD FILE NAME _____				

PROFILE		BY		DATE	
NO. _____		SURVEYED _____			
		PLOTTED _____			
	NOTE BOOK	GRADES CHECKED _____			
		B.M. NOTED _____			
		STRUCTURE NOTATIONS CHKD _____			

MODEL: Ramp_C_profile - Profile 1 [Sheet]
FILE NAME: p:\w\transystems\pw\benley.com\trans\scorp-pw\hosted\Documents\Projects_2018\CH401\401180022\03-WSP\CADD\62R23-2B-1\Sheets\Civil\012R23-EAST-drain\profile-rampC.pcdgn

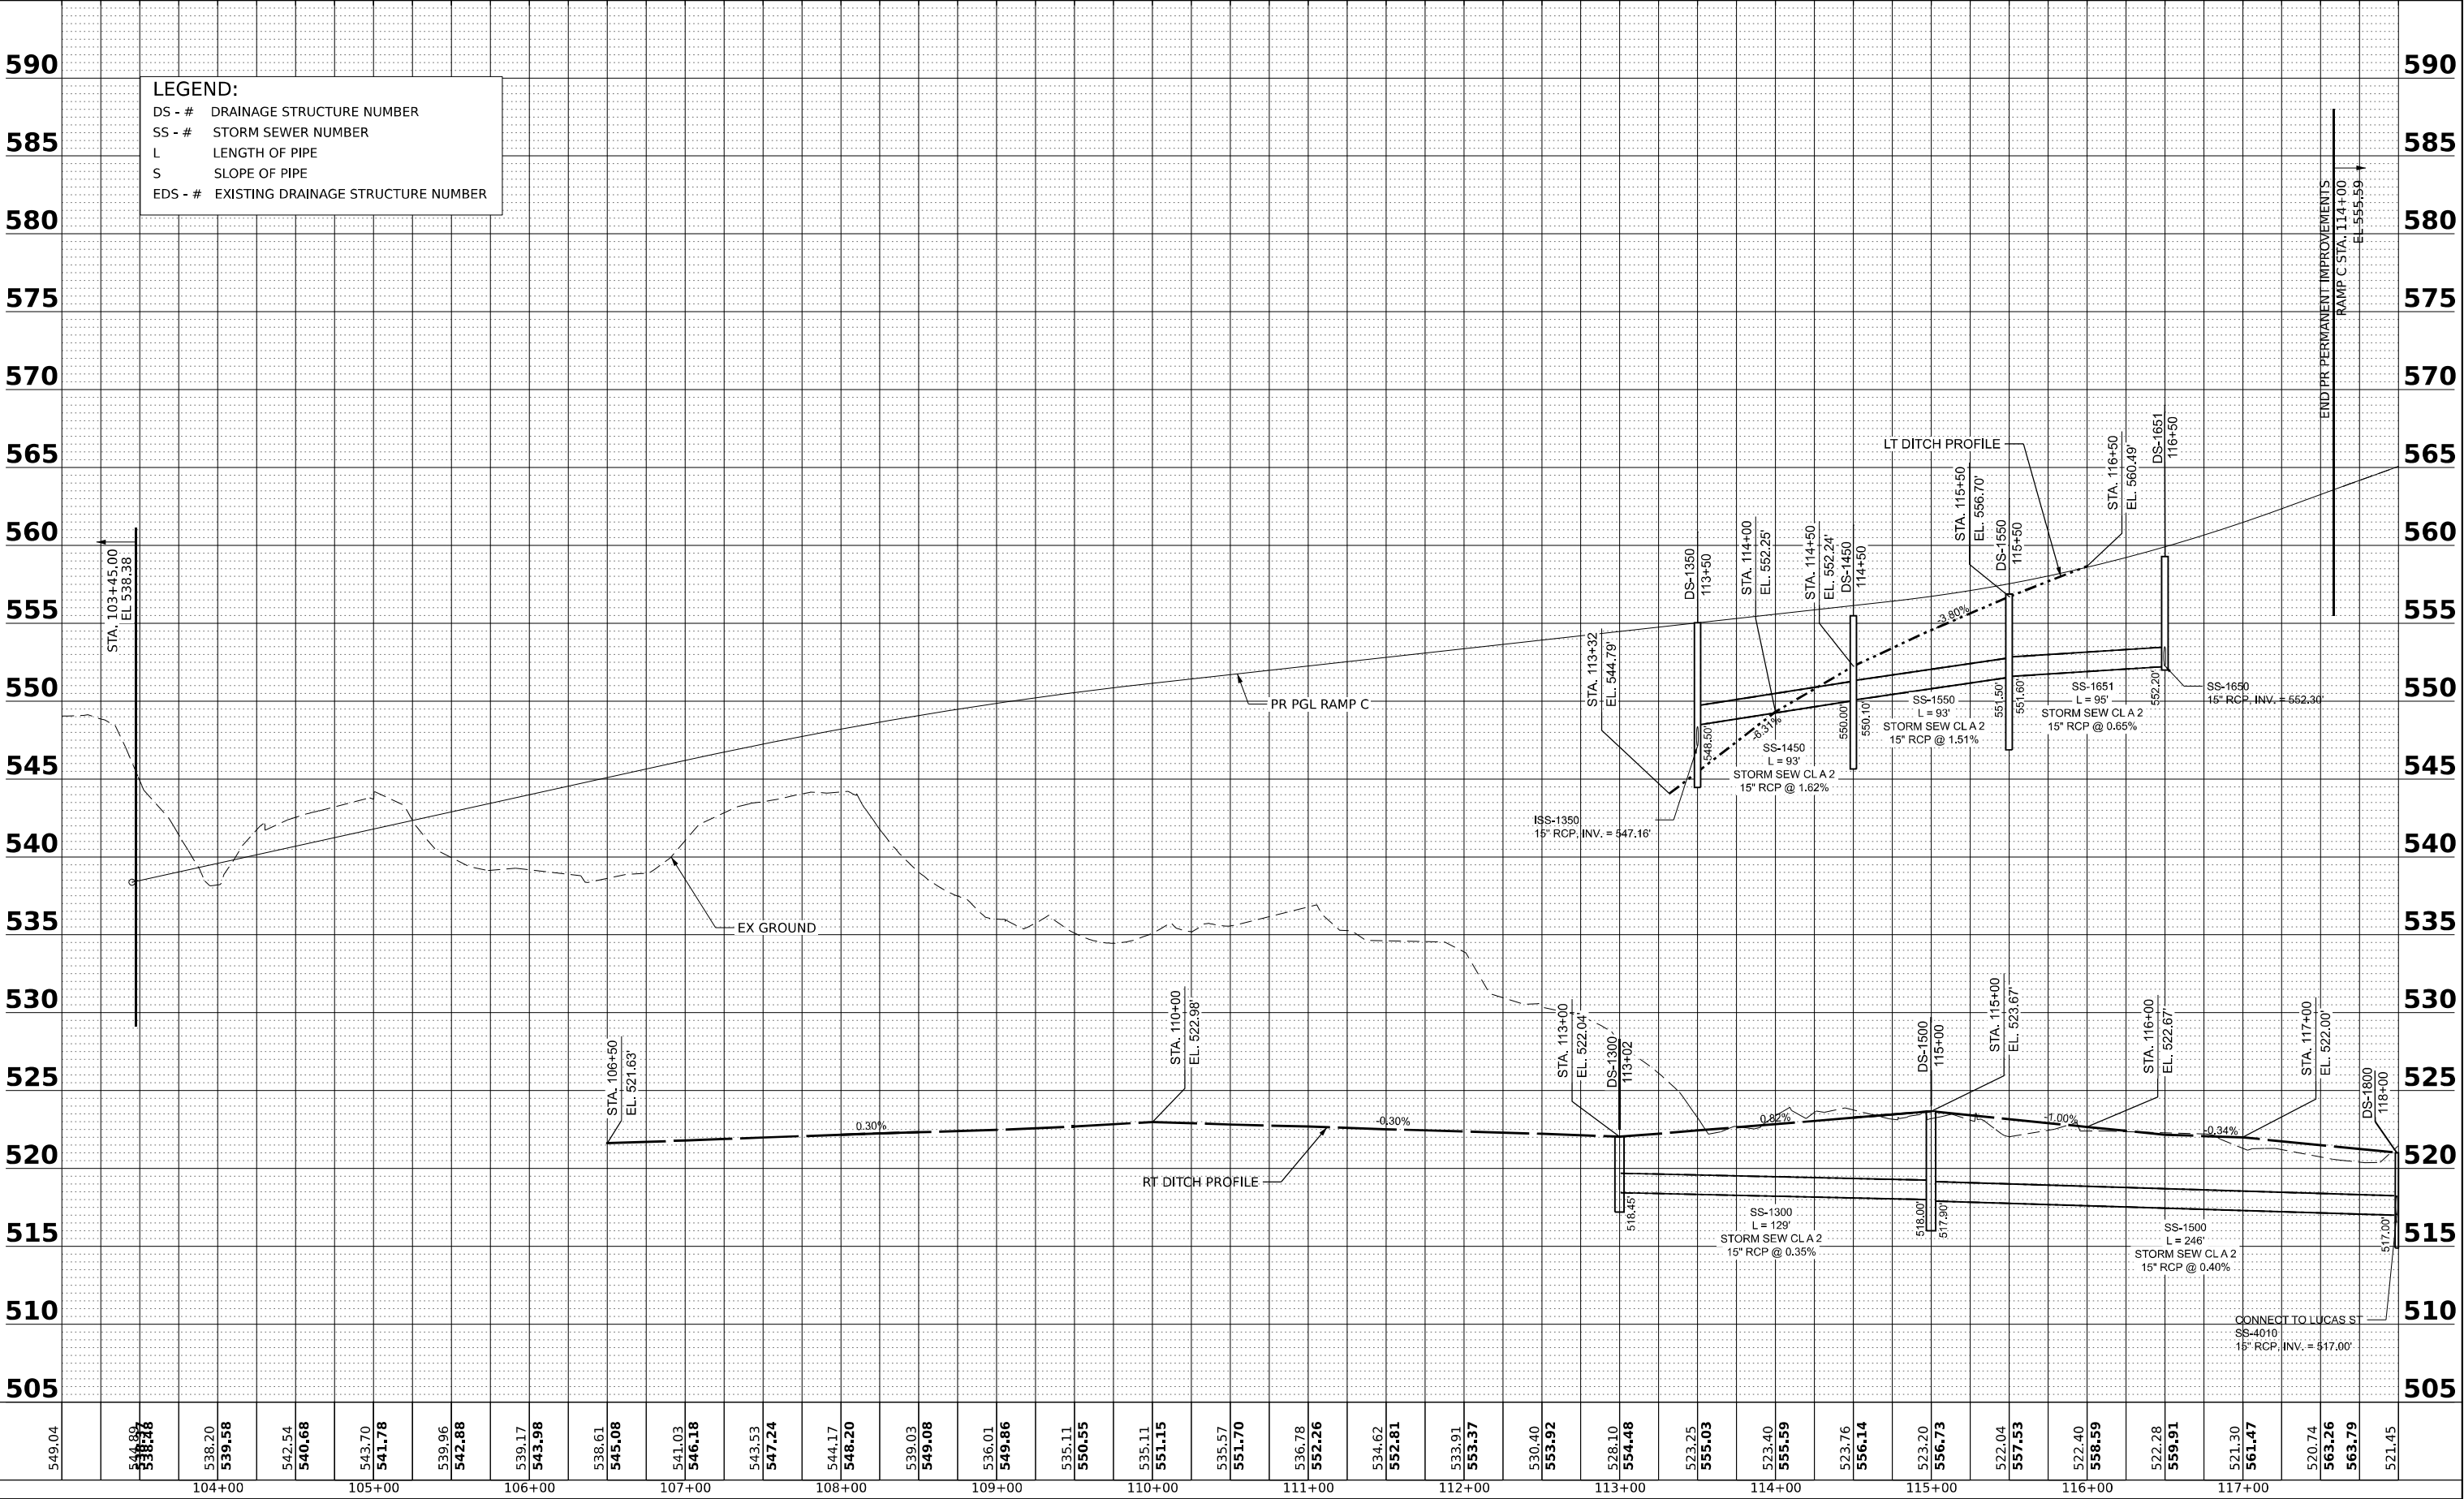


 WSP USA Inc. 30 N. LASALLE STREET SUITE 4200 CHICAGO, IL 60602 TEL: (312) 782-8150	USER NAME = USHC706648		DESIGNED - CJF	REVISED -	STATE OF ILLINOIS DEPARTMENT OF TRANSPORTATION	PROPOSED DRAINAGE PROFILE RAMP C				F.A.I. RTE.	SECTION	COUNTY	TOTAL SHEETS	SHEET NO.
			DRAWN - CJF	REVISED -		80	FAI 80 21 STRUCTURE 2	WILL	1230	344				
	PLOT SCALE = 0.16666667' / in.		CHECKED - JIR	REVISED -		CONTRACT NO. 62R23								
	PLOT DATE = 11/6/2025		DATE - 11/7/2025	REVISED -		SCALE: HORIZ: 1"=50' VERT: 1"=5'	SHEET 1 OF 1 SHEETS	STA.	TO STA.					
											ILLINOIS	FED. AID PROJECT		

PLAN	SURVEYED PLOTTED	ALIGNMENT CHECKED BY	DATE
NO.	NO.	NO.	NO.

PROFILE	SURVEYED PLOTTED	GRADES CHECKED BY	DATE
NO.	NO.	NO.	NO.

MODEL Ramp A - Profile 1 (Sheet)
FILE NAME: p:\projects\trans\trans\scorp-pw\sheet\Documents\Projects\2018\CH401\401180022\03-WSP\CAD\62R23-R2-1-Sheet\Civil\012R23-EAST-drain\profile-ramp\p.dgn

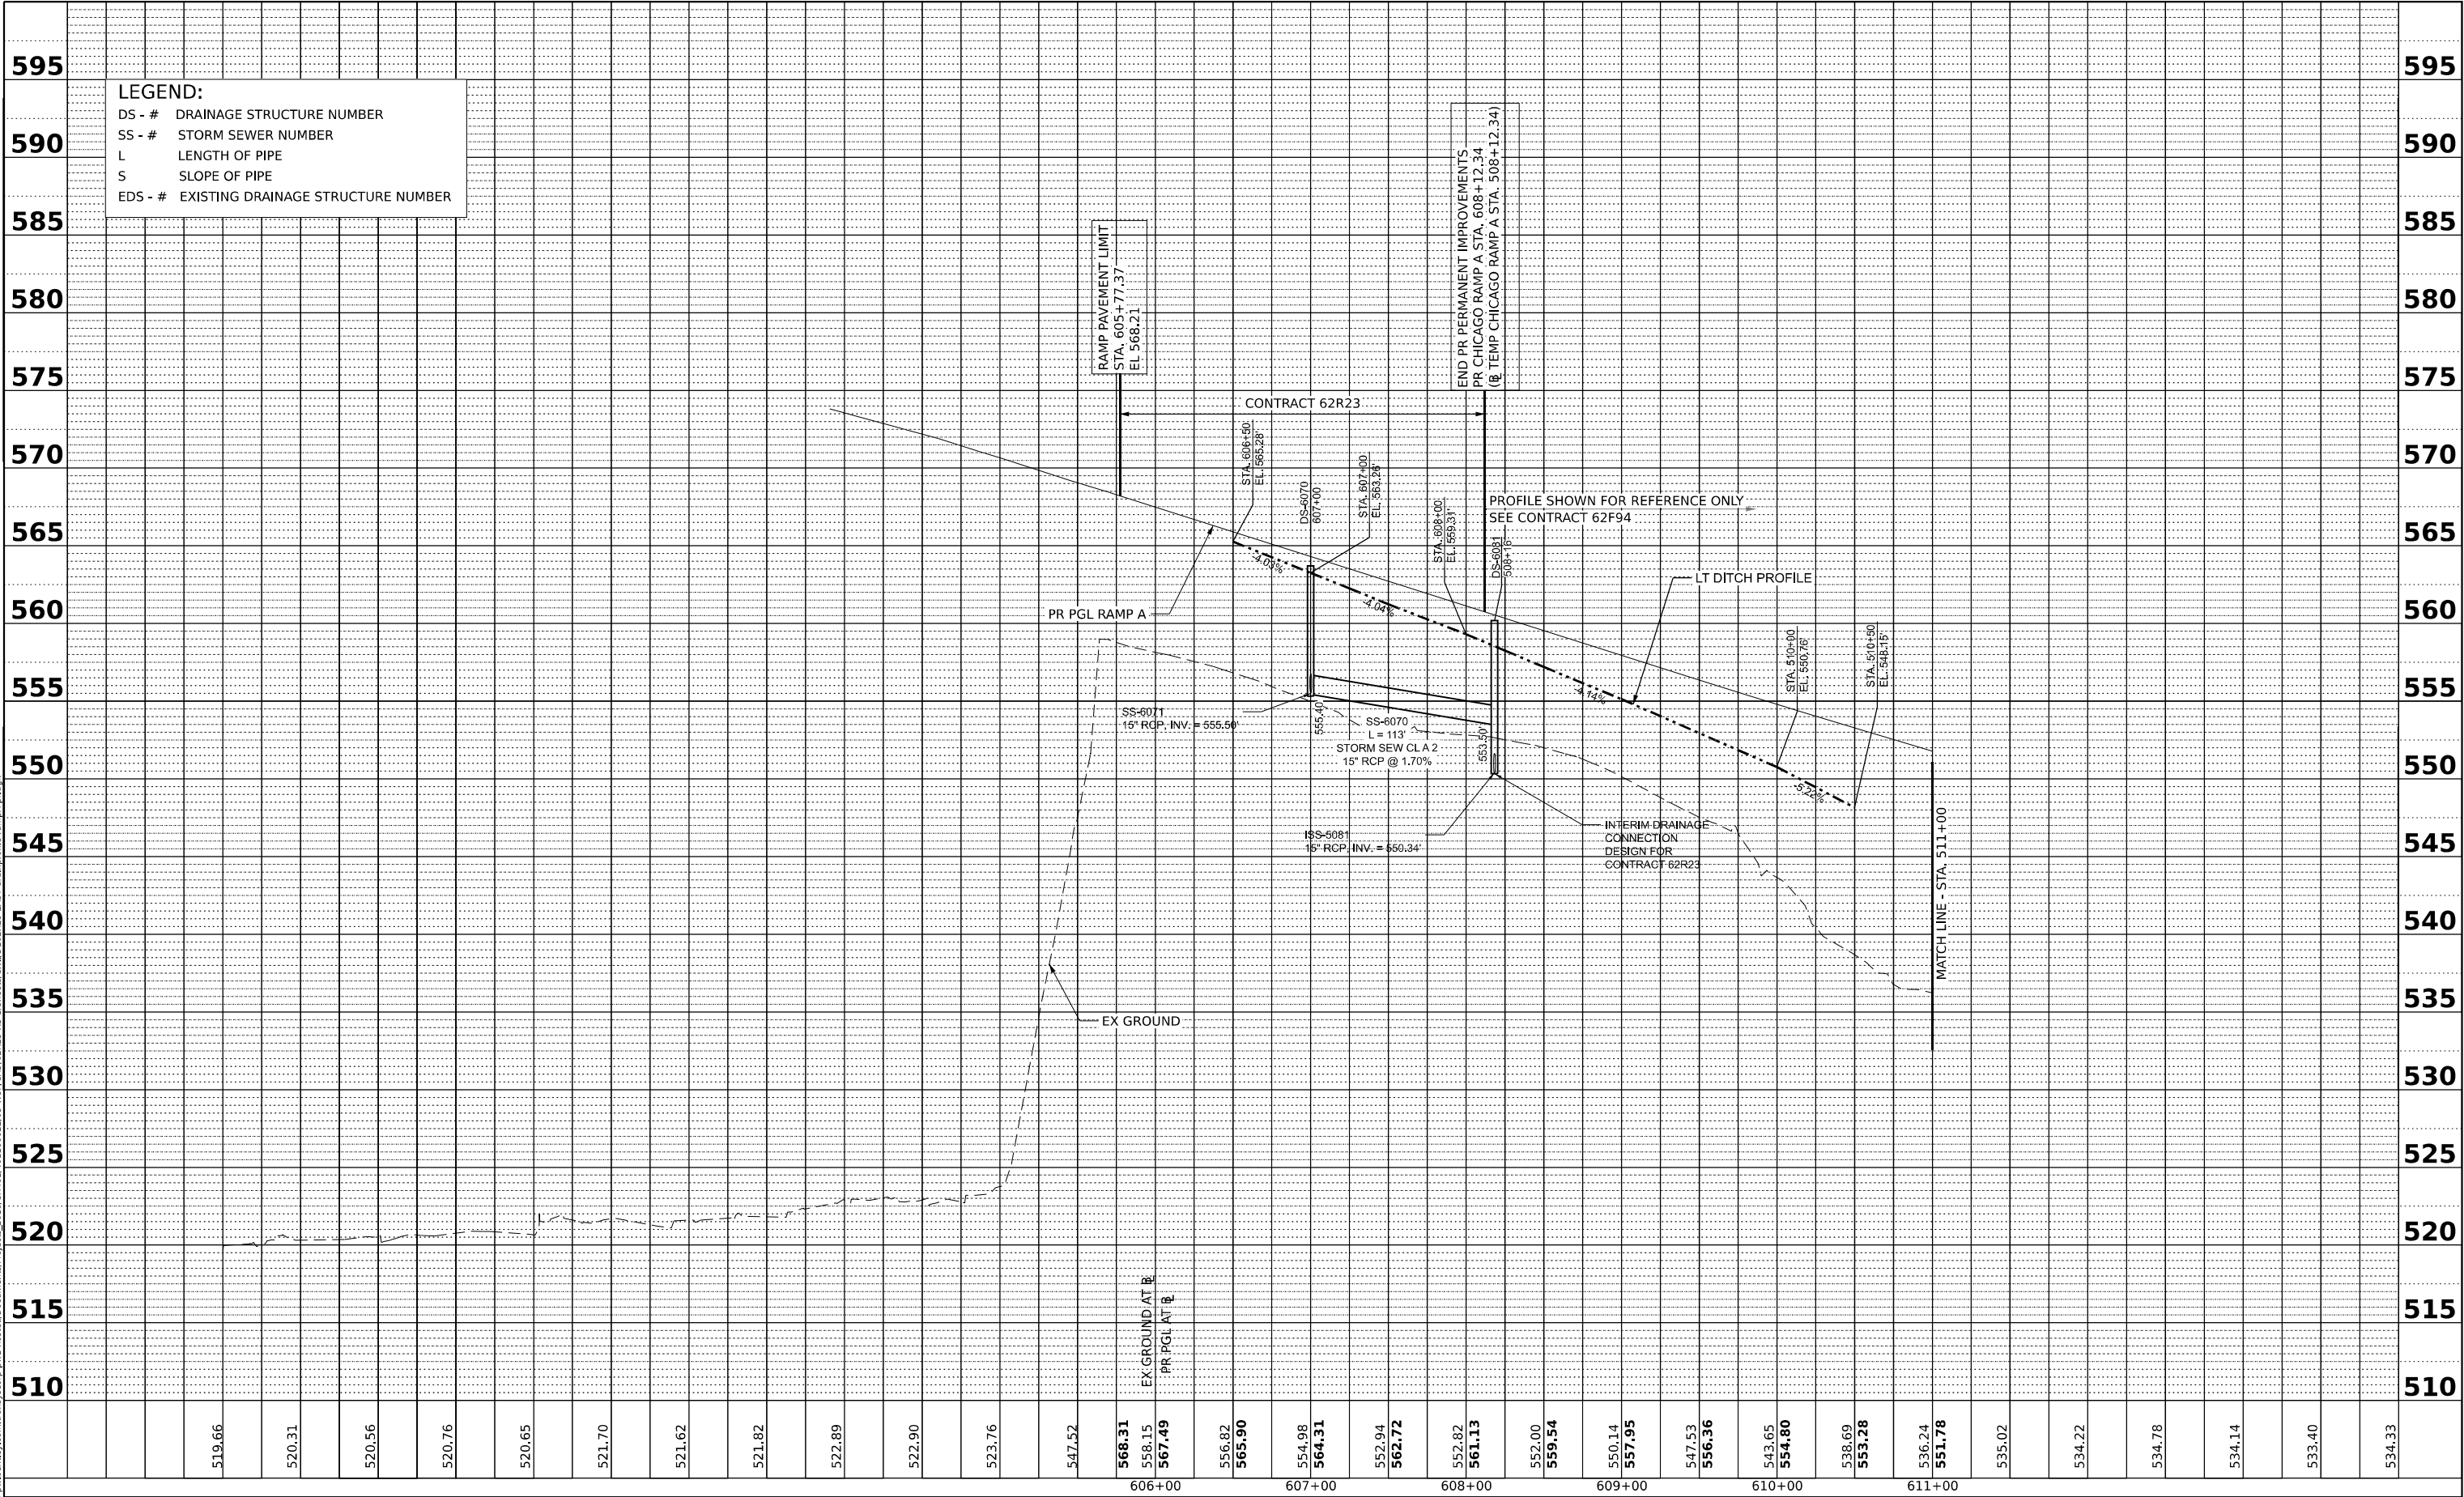

 WSP USA INC. 30 N. LASALLE STREET SUITE 4200 CHICAGO, IL 60602 TEL: (312) 782-8150	USER NAME = USHC706648		DESIGNED - HC	REVISED -
	PLOT SCALE = 0.16666667' / in.		DRAWN - HC	REVISED -
	PLOT DATE = 11/6/2025		CHECKED - KS	REVISED -
			DATE - 11/7/2025	REVISED -
	STATE OF ILLINOIS DEPARTMENT OF TRANSPORTATION			
PROPOSED DRAINAGE PROFILE RAMP A				
SCALE: HORIZ: 1"=50' VERT: 1"=5'		SHEET 1 OF 1 SHEETS	STA. TO STA.	
F.A.I. RTE. 80	SECTION FAI 80 21 STRUCTURE 2	COUNTY WILL	TOTAL SHEETS 1230	SHEET NO. 345
CONTRACT NO. 62R23				
ILLINOIS FED. AID PROJECT				

LEGEND

- PR. INLET

PR. CATCH BASIN

PR. MANHOLE

PR. UNDERDRAIN HEADWALL

PR. END SECTION

PR. SWALE

PR. DITCH
- PR. STORM SEWER

PR. PIPE UNDERDRAIN

PR. RIP RAP APRON

XXXX


PR. STRUCTURE

XXXX

PR. PIPE

UC

UTILITY CROSSING

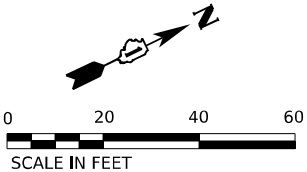

DS-2151
STA. 215+34, 28.2' LT
CB TA 4 DIA T8G
RIM = 538.51
INV. = 535.18 (E)

DS-2150
STA. 215+34, 15.0' LT
MAN TA 6 DIA T1F CL
RIM = 539.18
INV. = 535.13 (N, W)

DS-2171
STA. 217+01, 28.2' LT
CB TA 4 DIA T8G
RIM = 539.87
INV. = 534.91 (E)

DS-2170
STA. 217+01, 15.5' LT
MAN TA 6 DIA T1F CL
RIM = 539.58
INV. = 534.86 (S, E, W)

DS-2172
STA. 217+25, 54.2' RT
CONC ES 542001 30 1:4
TRAVERSABLE PIPE GRATE
INV. = 534.73

SS-2151
SS CL A 1 EQRS 18
9' @ 0.55%
TBF = 1.0 CY

SS-2150
SS CL A 1 EQRS 24
162' @ 0.17%
TBF = 34.5 CY

SS-2171
SS CL A 1 EQRS 18
9' @ 0.61%
TBF = 2.7 CY

SS-2170
STORM SEW WM REQ 30
66' @ 0.20%
TBF = 6.0 CY

BEGIN IMPROVEMENT
STA. 214+54.07

NOTES:

1. FOR PLACEMENT OF DRAINAGE STRUCTURE, SEE SHEET 383
2. FOR RIPRAP DETAILS, SEE SHEET 384
3. UC: PROPOSED STORM SEWER CONFLICT WITH PROPOSED CITY OF JOLIET UTILITIES;
REFER TO JOLIET DRAINAGE AND UTILITY PLANS

US-6 UTILITY CROSSING TABLE								
CROSSING NUMBER	LOCATION		PIPE INFORMATION			INVERT ELEVATION	OUTER ELEVATION	CLEARANCE (FEET)
	STATION	OFFSET	STATUS	SIZE	TYPE			
UC-1	217+08	6.0 RT	PR	EQRS 30"	STORM	534.82	534.51	9.79
			EX	72"	SANITARY	518.72	524.72	
UC-2	217+13	21.0 RT	PR	EQRS 30"	STORM	534.78	534.47	APPROX 1.5
			PR	12"	WATER	+/- 531.97	+/- 532.97	
UC-3	217+14	24.8 RT	PR	EQRS 30"	STORM	534.78	534.47	2.07
			PR	4"	GAS	532.07	532.40	

	WSP USA INC. 30 N. LASALLE STREET SUITE 4200 CHICAGO, IL 60602 TEL: (312) 782-8150	USER NAME = USHC706648	DESIGNED - AKG	REVISED -
		PLOT SCALE = 40,000' / in.	DRAWN - SSM	REVISED -
		PLOT DATE = 11/6/2025	CHECKED - KS	REVISED -
			DATE - 11/7/2025	REVISED -

STATE OF ILLINOIS
DEPARTMENT OF TRANSPORTATION



PROPOSED DRAINAGE AND UTILITY PLAN
US-6

SCALE: 1"=20' SHEET 1 OF 4 SHEETS STA. TO STA.

F.A.I. RTE.	SECTION	COUNTY	TOTAL SHEETS	SHEET NO.
80	FAI 80 21 STRUCTURE 2	WILL	1230	346
CONTRACT NO. 62R23				
ILLINOIS		FED. AID PROJECT		

LEGEND

PR. INLET	PR. STORM SEWER
PR. CATCH BASIN	PR. PIPE UNDERDRAIN
PR. MANHOLE	PR. RIP RAP APRON
PR. UNDERDRAIN HEADWALL	PR. STRUCTURE
PR. END SECTION	PR. PIPE
PR. SWALE	UTILITY CROSSING
PR. DITCH	

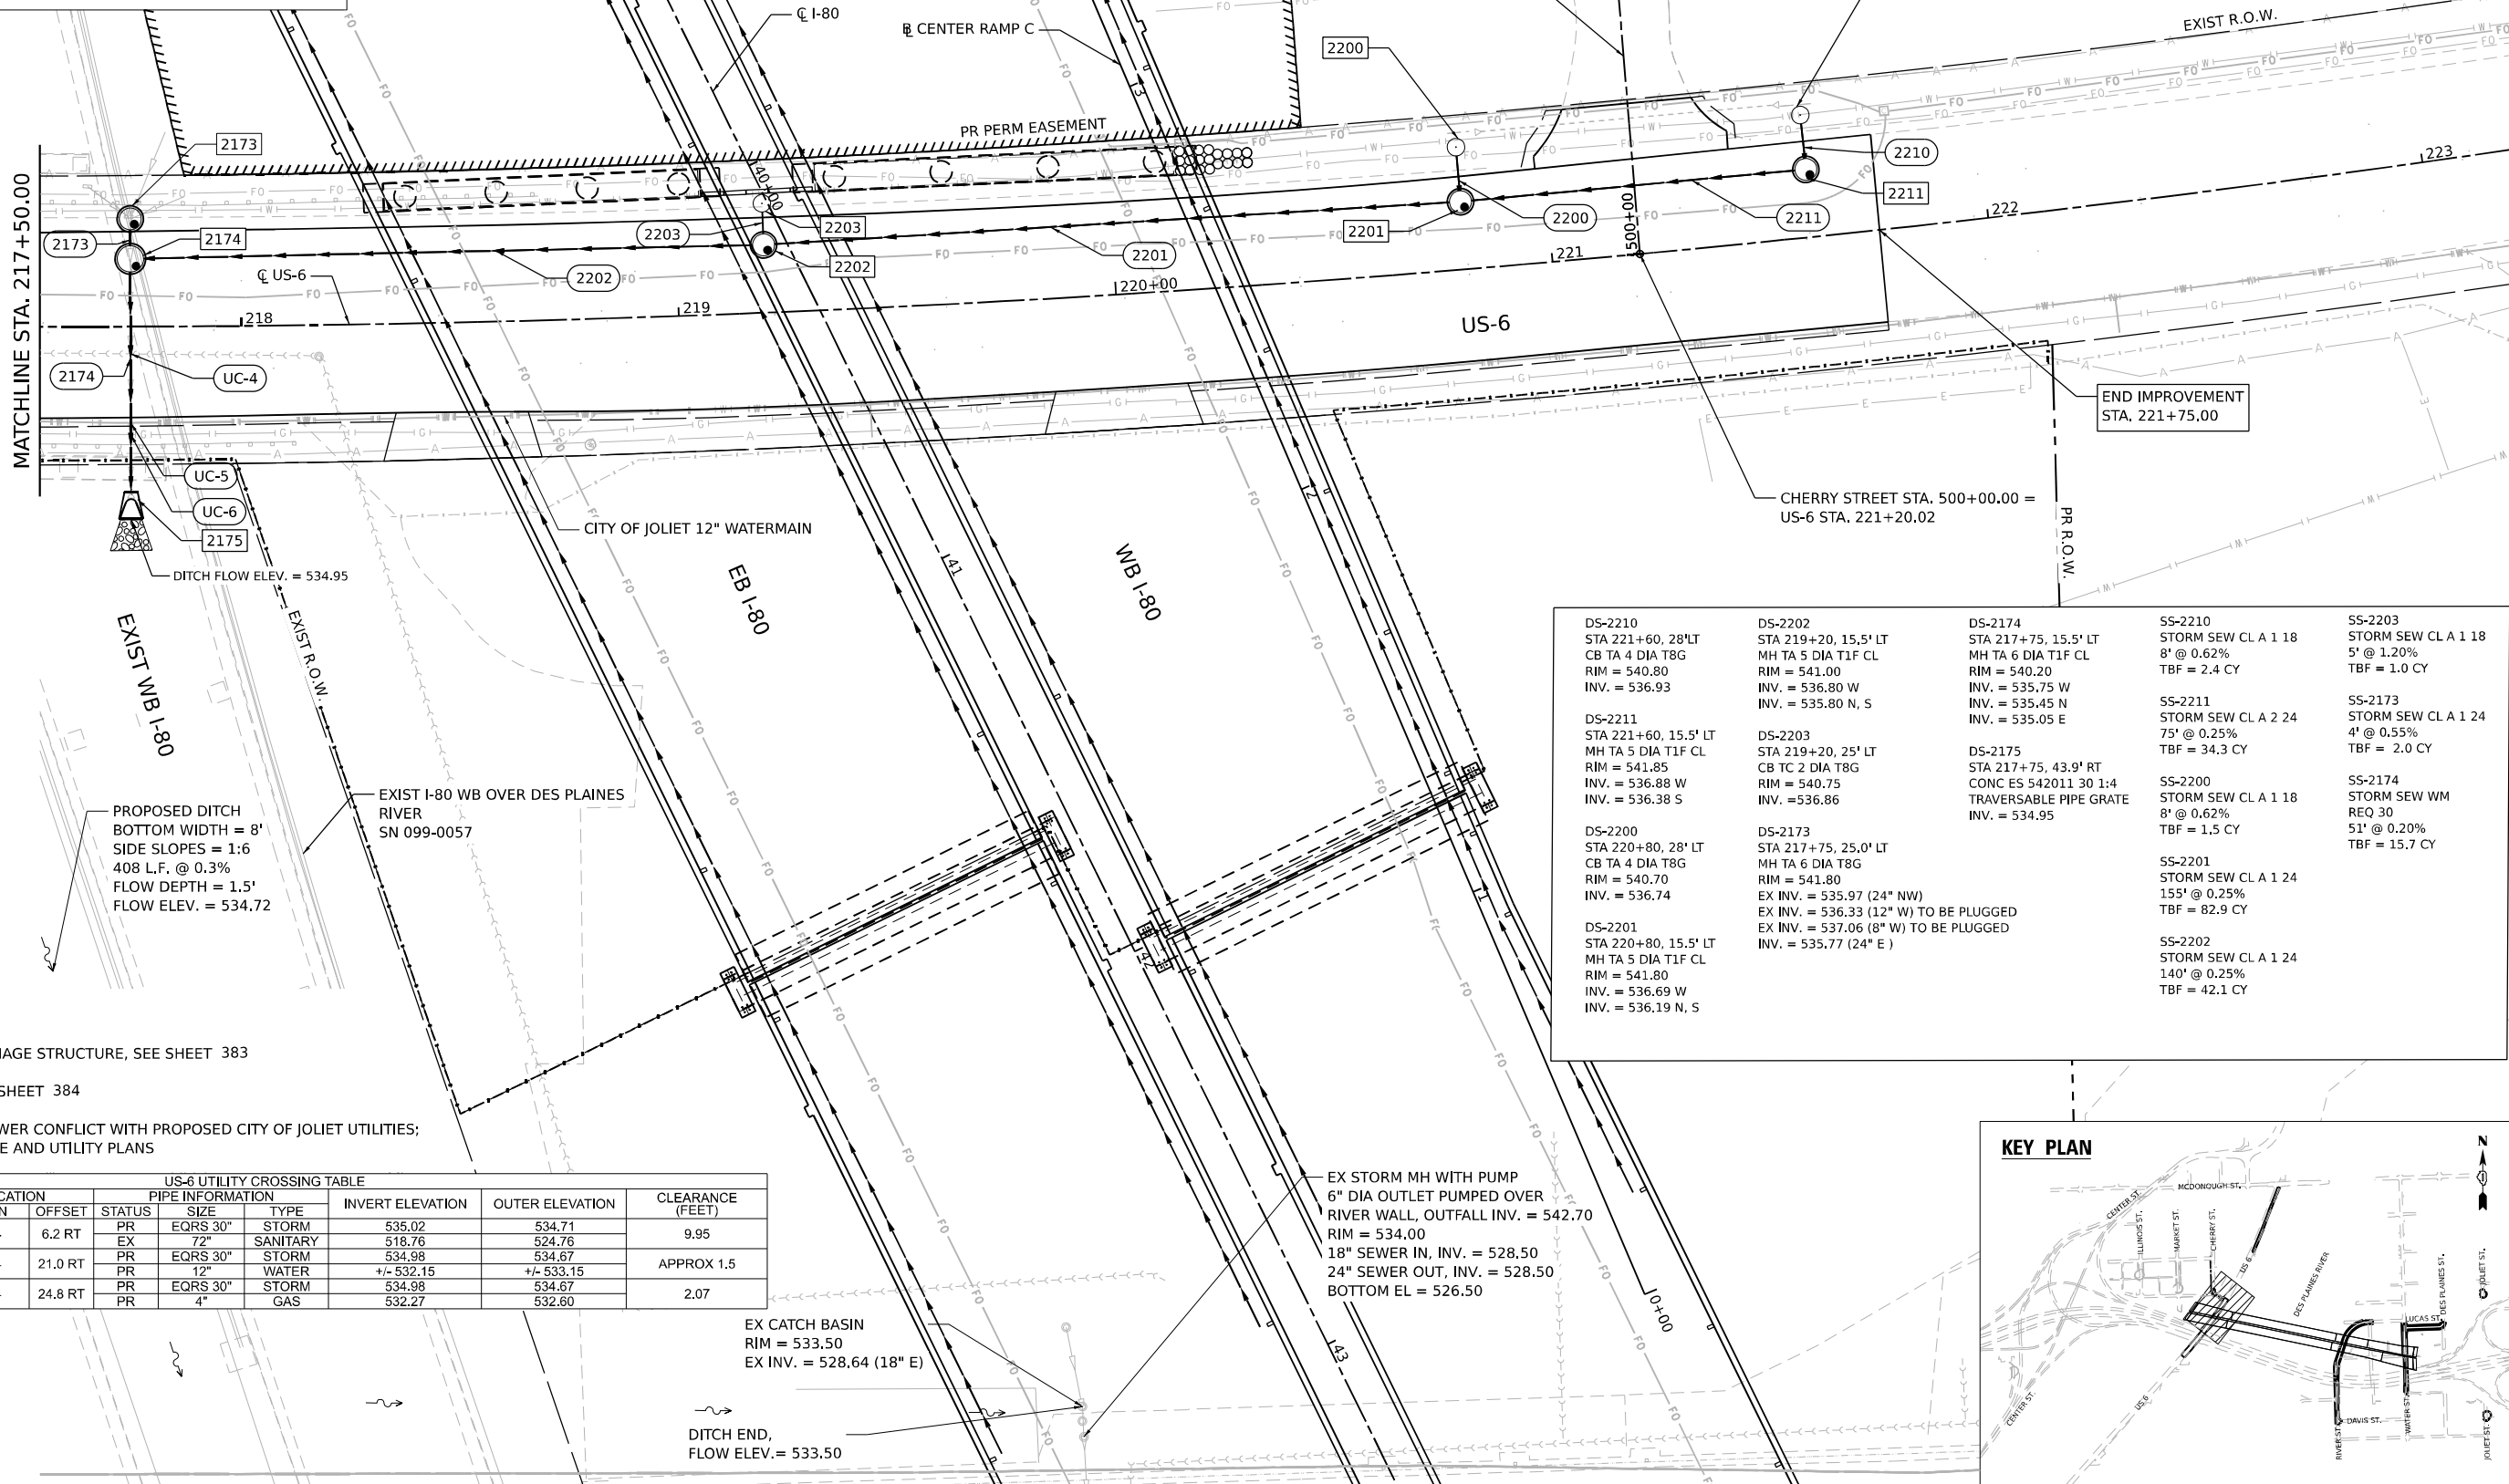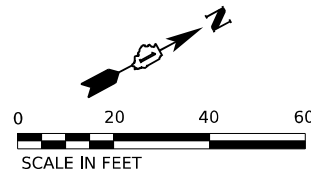

NOTES:

- FOR PLACEMENT OF DRAINAGE STRUCTURE, SEE SHEET 383
- FOR RIPRAP DETAILS, SEE SHEET 384
- UC: PROPOSED STORM SEWER CONFLICT WITH PROPOSED CITY OF JOLIET UTILITIES; REFER TO JOLIET DRAINAGE AND UTILITY PLANS

US-6 UTILITY CROSSING TABLE							
CROSSING NUMBER	LOCATION		PIPE INFORMATION		INVERT ELEVATION	OUTER ELEVATION	CLEARANCE (FEET)
	STATION	OFFSET	STATUS	SIZE TYPE			
UC-4	217+74	6.2 RT	PR	EQRS 30"	535.02	534.71	9.95
			EX	72" SANITARY	518.76	524.76	
UC-5	217+74	21.0 RT	PR	EQRS 30"	534.98	534.67	APPROX 1.5
			PR	12" WATER	+/- 532.15	+/- 533.15	
UC-6	217+74	24.8 RT	PR	EQRS 30"	534.98	534.67	2.07
			PR	4" GAS	532.27	532.60	


EX CATCH BASIN
RIM = 533.50
EX INV. = 528.64 (18" E)

DITCH END,
FLOW ELEV.= 533.50

EX STORM MH WITH PUMP
6" DIA OUTLET PUMPED OVER
RIVER WALL, OUTFALL INV. = 542.70
RIM = 534.00
18" SEWER IN, INV. = 528.50
24" SEWER OUT, INV. = 528.50
BOTTOM EL = 526.50

DS-2210 STA 221+60, 28' LT CB TA 4 DIA T8G RIM = 540.80 INV. = 536.93	DS-2202 STA 219+20, 15.5' LT MH TA 5 DIA T1F CL RIM = 541.00 INV. = 536.80 W INV. = 535.80 N, S	DS-2174 STA 217+75, 15.5' LT MH TA 6 DIA T1F CL RIM = 540.20 INV. = 535.75 W INV. = 535.45 N INV. = 535.05 E	SS-2210 STORM SEW CL A 1 18 8' @ 0.62% TBF = 2.4 CY	SS-2203 STORM SEW CL A 1 18 5' @ 1.20% TBF = 1.0 CY
DS-2211 STA 221+60, 15.5' LT MH TA 5 DIA T1F CL RIM = 541.85 INV. = 536.88 W INV. = 536.38 S	DS-2203 STA 219+20, 25' LT CB TC 2 DIA T8G RIM = 540.75 INV. = 536.86	DS-2175 STA 217+75, 43.9' RT CONC ES 542011 30 1:4 TRAVERSABLE PIPE GRATE INV. = 534.95	SS-2211 STORM SEW CL A 2 24 75' @ 0.25% TBF = 34.3 CY	SS-2173 STORM SEW CL A 1 24 4' @ 0.55% TBF = 2.0 CY
DS-2200 STA 220+80, 28' LT CB TA 4 DIA T8G RIM = 540.70 INV. = 536.74	DS-2173 STA 217+75, 25.0' LT MH TA 6 DIA T8G RIM = 541.80 EX INV. = 535.97 (24" NW) EX INV. = 536.33 (12" W) TO BE PLUGGED EX INV. = 537.06 (8" W) TO BE PLUGGED INV. = 535.77 (24" E)		SS-2200 STORM SEW CL A 1 18 8' @ 0.62% TBF = 1.5 CY	SS-2174 STORM SEW WM REQ 30 51' @ 0.20% TBF = 15.7 CY
DS-2201 STA 220+80, 15.5' LT MH TA 5 DIA T1F CL RIM = 541.80 INV. = 536.69 W INV. = 536.19 N, S			SS-2201 STORM SEW CL A 1 24 155' @ 0.25% TBF = 82.9 CY	
			SS-2202 STORM SEW CL A 1 24 140' @ 0.25% TBF = 42.1 CY	

KEY PLAN

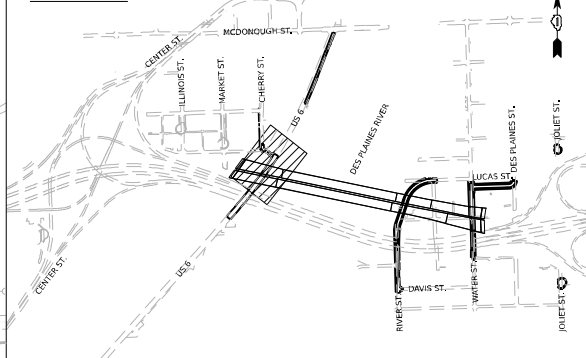

WSP USA INC.
30 N. LASALLE STREET
SUITE 4700
CHICAGO, IL 60602
TEL: (312) 782-8150

USER NAME = USHC706648
DESIGNED - AKG
DRAWN - SSM
CHECKED - KS
DATE - 11/7/2025

DESIGNED - AKG
DRAWN - SSM
CHECKED - KS
DATE - 11/7/2025

DESIGNED - AKG
DRAWN - SSM
CHECKED - KS
DATE - 11/7/2025

STATE OF ILLINOIS
DEPARTMENT OF TRANSPORTATION

PROPOSED DRAINAGE AND UTILITY PLAN
US-6

SCALE: 1"=20'

SHEET 2 OF 4 SHEETS

STA.

TO STA.

F.A.I.
RTE.

80

SECTION
FAI 80 21 STRUCTURE 2

COUNTY

WILL

TOTAL
SHEETS

1230


SHEET
NO.

347

CONTRACT NO. 62R23

ILLINOIS

FED. AID PROJECT

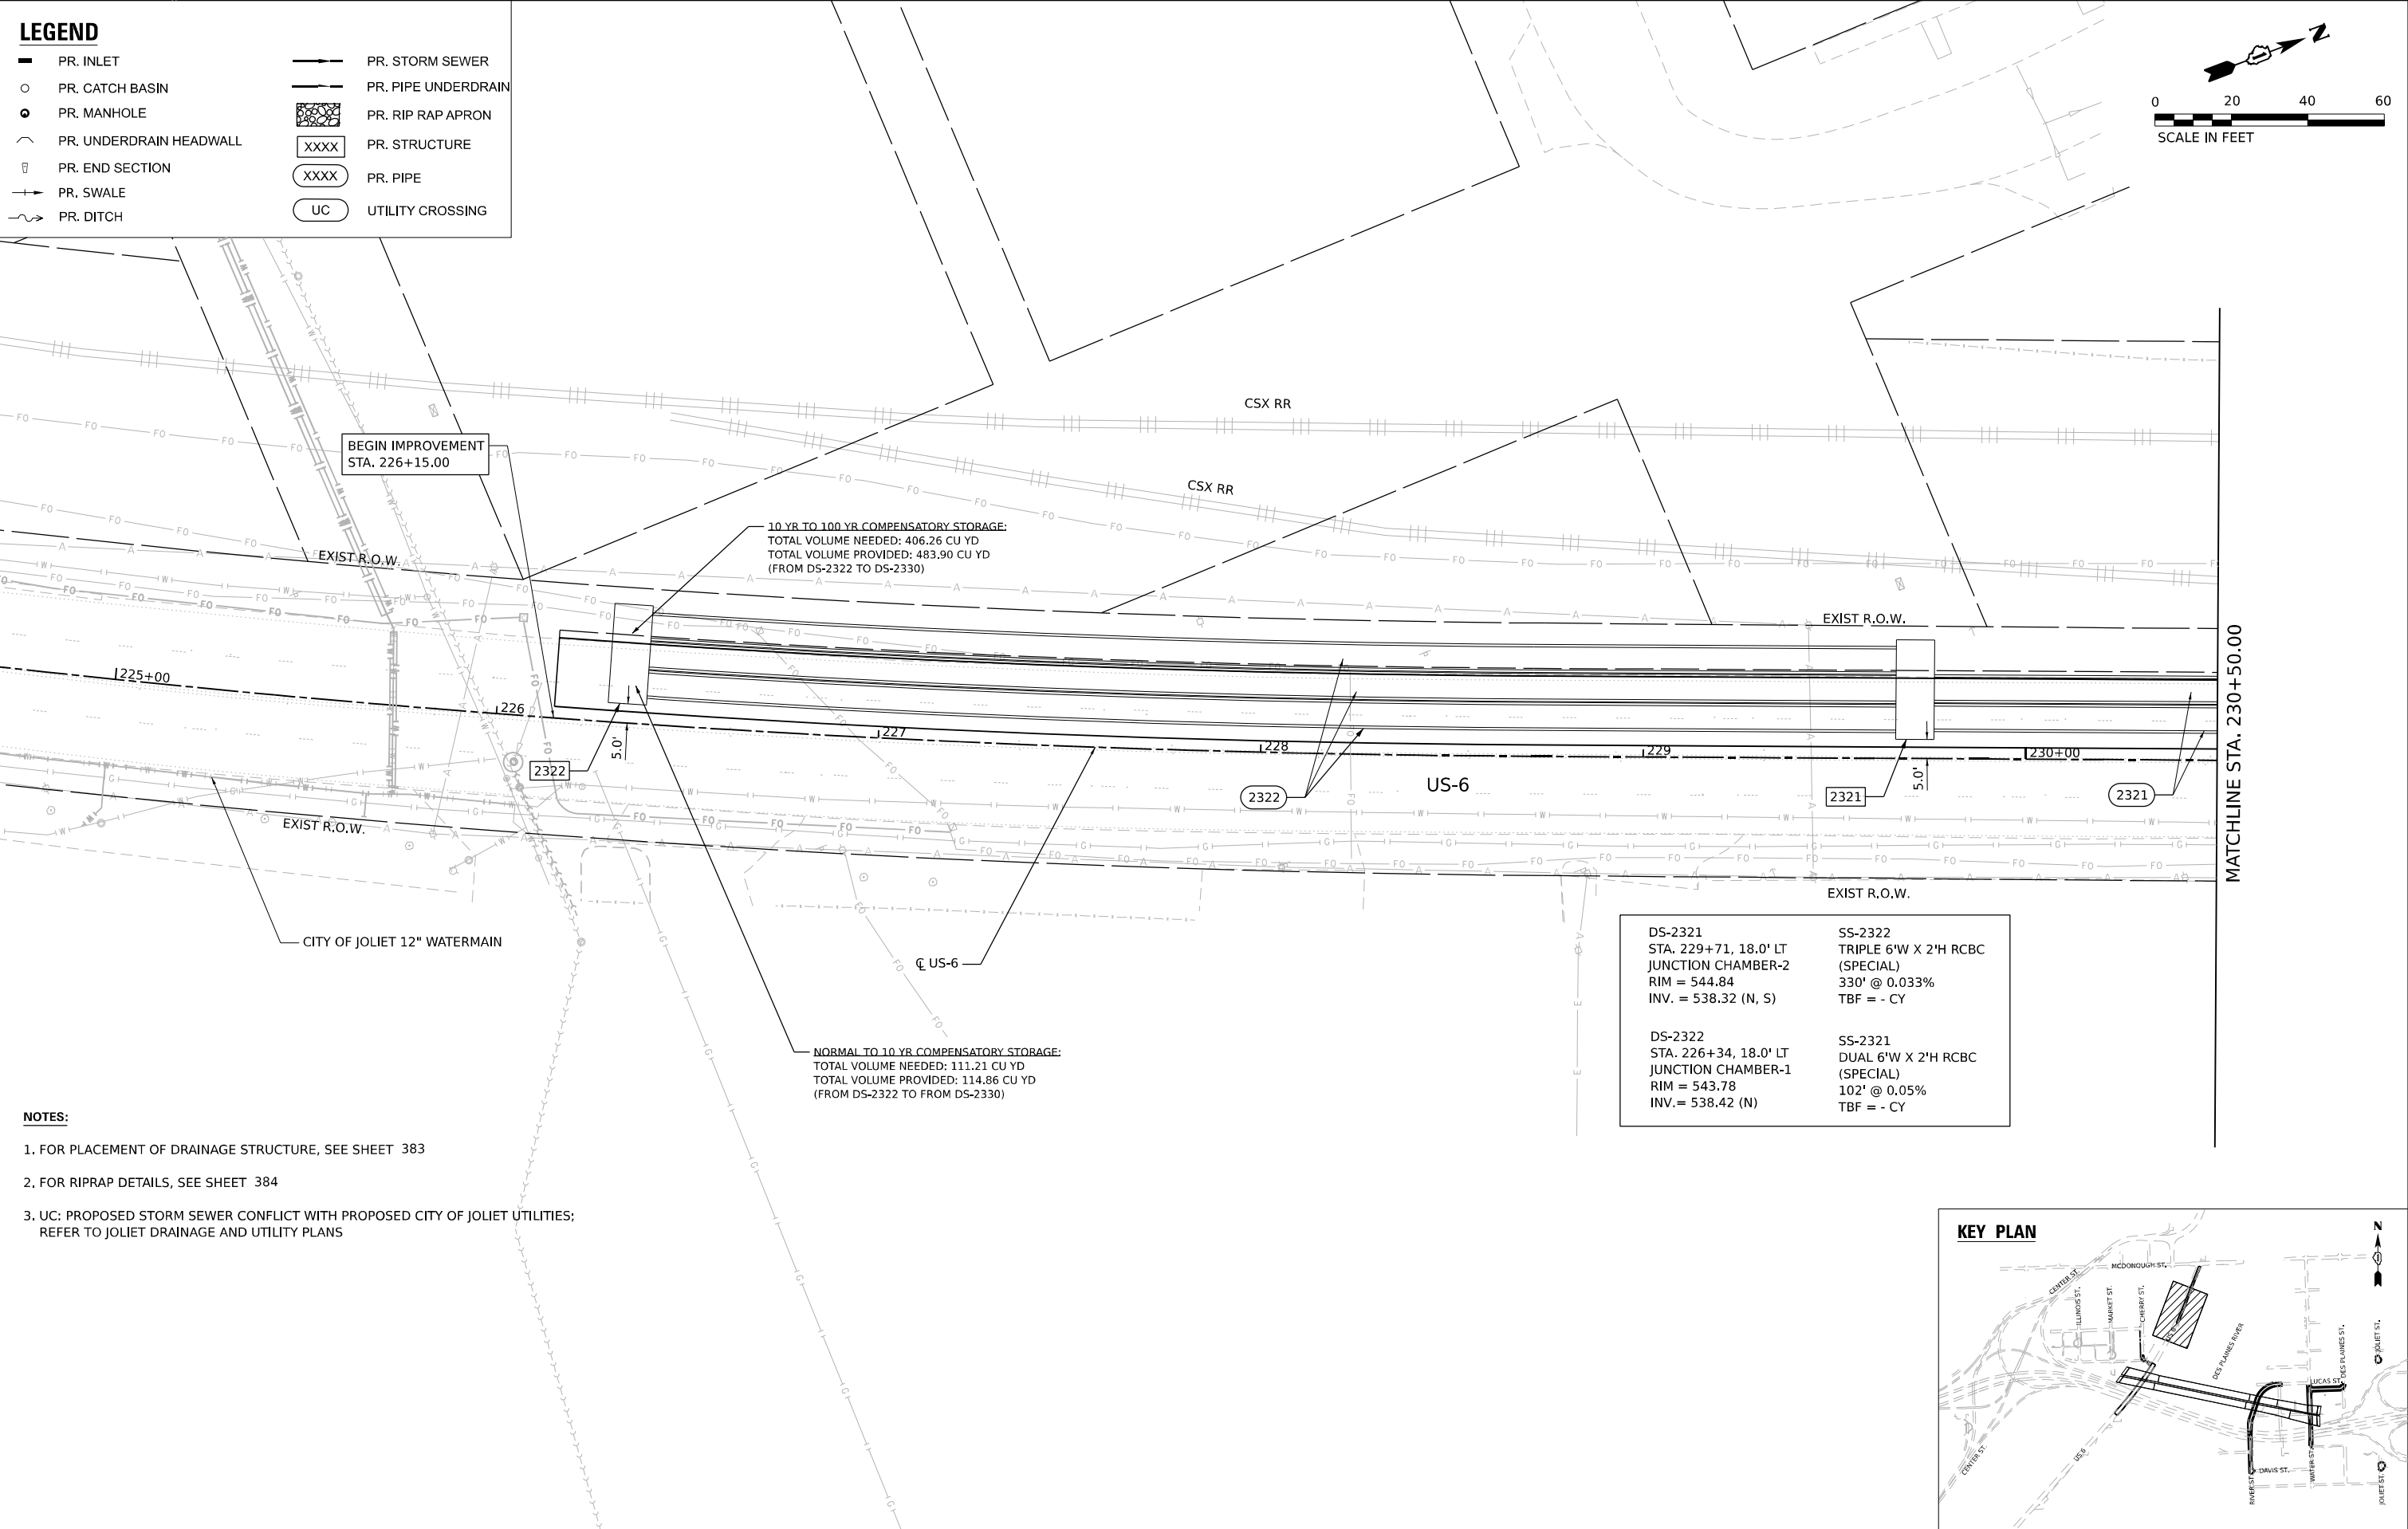

- NOTES:**
1. FOR PLACEMENT OF DRAINAGE STRUCTURE, SEE SHEET 383
 2. FOR RIPRAP DETAILS, SEE SHEET 384
 3. UC: PROPOSED STORM SEWER CONFLICT WITH PROPOSED CITY OF JOLIET UTILITIES; REFER TO JOLIET DRAINAGE AND UTILITY PLANS

	WSP USA INC. 30 N. LA SALLE STREET SUITE 4200 CHICAGO, IL 60602 TEL: (312) 782-8150	USER NAME = USHC706648	DESIGNED - AKG	REVISED -	STATE OF ILLINOIS DEPARTMENT OF TRANSPORTATION	PROPOSED DRAINAGE AND UTILITY PLAN			F.A.I. RTE.	SECTION	COUNTY	TOTAL SHEETS	SHEET NO.
		PLOT SCALE = 40,000' / in.	DRAWN - SSM	REVISED -		US-6			80	FAI 80 21 STRUCTURE 2	WILL	1230	348
		PLOT DATE = 11/6/2025	CHECKED - KS	REVISED -		SCALE: 1"=20'			CONTRACT NO. 62R23				
			DATE - 11/7/2025	REVISED -		SHEET 3 OF 4 SHEETS	STA.	TO STA.	ILLINOIS FED. AID PROJECT				

LEGEND

PR. INLET

PR. CATCH BASIN

PR. MANHOLE

PR. UNDERDRAIN HEADWALL

PR. END SECTION

PR. SWALE

PR. DITCH

PR. STORM SEWER

PR. PIPE UNDERDRAIN

PR. RIP RAP APRON

XXXX

PR. STRUCTURE

XXXX

PR. PIPE

UC

UTILITY CROSSING

0

20

40

60

SCALE IN FEET

NOTES:

- 1. FOR PLACEMENT OF DRAINAGE STRUCTURE, SEE SHEET 383
- 2. FOR RIPRAP DETAILS, SEE SHEET 384
- 3. UC: PROPOSED STORM SEWER CONFLICT WITH PROPOSED CITY OF JOLIET UTILITIES; REFER TO JOLIET DRAINAGE AND UTILITY PLANS

US-6 UTILITY CROSSING TABLE							
CROSSING NUMBER	LOCATION		PIPE INFORMATION			INVERT ELEVATION	OUTER ELEVATION
	STATION	OFFSET	STATUS	SIZE	TYPE		
UC-7	223+31	36.3 RT	PR	42"	STORM	537.21	536.84
			PR	2"	GAS	533.73	533.90

DS-2330 STA. 233+12, 10.1' LT MAN TA 8 DIA T1F CL RIM = 544.50 EX INV. = 539.09 (40"W - APPROXIMATELY) INV. = 538.04 (24" S) INV. = 538.04 (42" E)	SS-2319 STORM SEW CL A 2 24 106' @ 0.17% TBF = 91.8 CY
DS-2332 STA. 233+46, 88.2' RT MAN TA 8 DIA T1F CL RIM = 542.68 INV. = 536.31 (42" W) EX INV. = 539.21 (12" N) EX INV. = 536.15 (36" E)	SS-2320 6'W X 2'H RCBC (SPECIAL) 114' @ 0.05% TBF = - CY
DS-2320 STA. 230+79, 14.5' LT JUNCTION CHAMBER-3 RIM = 545.82 INV. = 538.27 (N, S)	SS-2330 STORM SEW WM REQ 42 98' @ 1.77% TBF = 61.9 CY
DS-2319 STA. 231+99, 10.5' LT JUNCTION CHAMBER-4 RIM = 545.82 INV. = 538.22 (N, S)	

MODEL: Default
FILE NAME: p:\projects\trans\scorp\p1\hatched\Documents\Projects_2018\CH4001401180022\03-MS9\CD\62R23-RB-1_Sheets\CD\62R23-shd\mainplan13-2.dgn

WSP

WSP USA INC.
30 N. LA SALLE STREET
SUITE 4200
CHICAGO, IL 60602
TEL: (312) 782-8150

USER NAME = USHC706648

DESIGNED - AKG

DRAWN - SSM

CHECKED - KS

DATE - 11/7/2025

REVISED -

REVISED -

REVISED -

REVISED -

STATE OF ILLINOIS
DEPARTMENT OF TRANSPORTATION

PROPOSED DRAINAGE AND UTILITY PLAN
US-6

SCALE: 1"=20'

SHEET 4 OF 4 SHEETS


STA. TO STA.

F.A.I. RTE.	SECTION	COUNTY	TOTAL SHEETS	SHEET NO.
80	FAI 80 21 STRUCTURE 2	WILL	1230	349
CONTRACT NO. 62R23				
ILLINOIS FED. AID PROJECT				

PLAN	SURVEYED	BY	DATE
	PLOTTED		
	ALIGNMENT CHECKED		
	CADD FILE NAME		
NOTE BOOK NO.			


PROFILE	SURVEYED	BY	DATE
	PLOTTED		
	GRADES CHECKED		
	STRUCTURE NOTATIONS CHECKED		
NOTE BOOK NO.			

MODEL US6_PFCU3 - US6_3 [Sheet]
FILE NAME: p:\civil\transystems\p\benley.com\transys\corp-pw1\hosed\Documents\Projects_2018\CH401\401180022\03-WSP\CAD\621623-1-RB-1\Sheets\Civil\01621623-shr-trainprofile-US-6.dgn

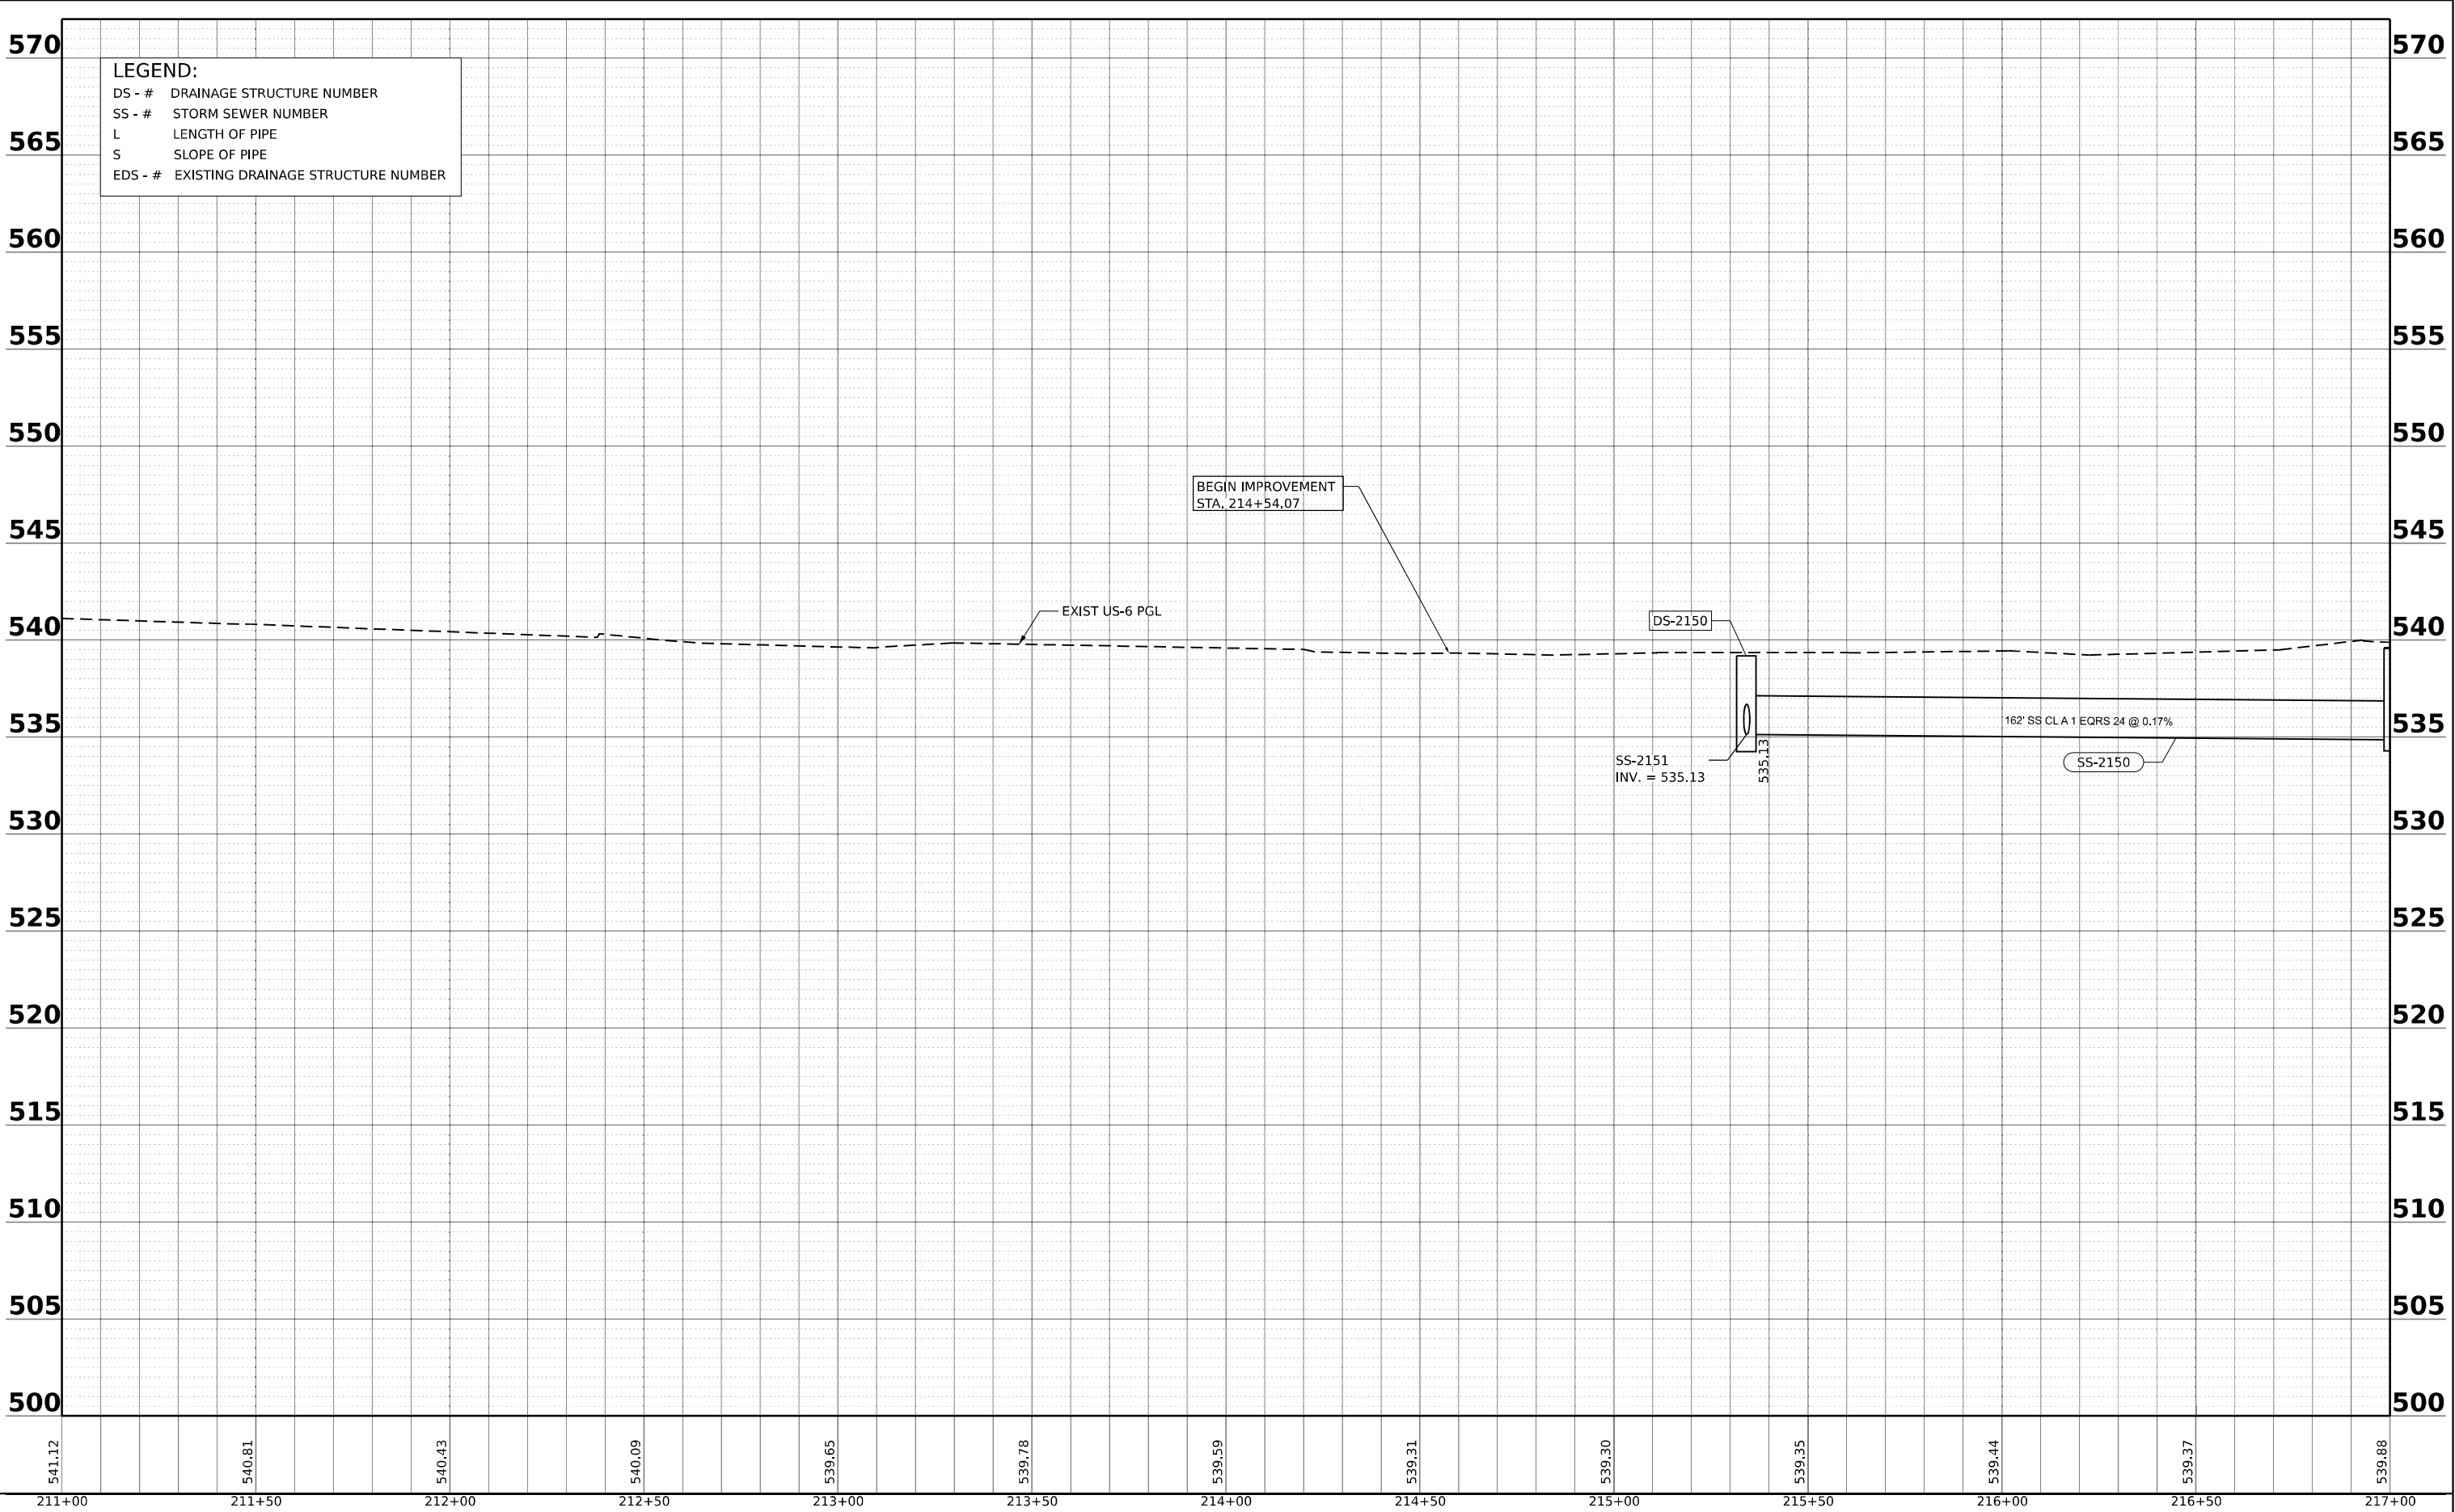

PROFILE	SURVEYED _____	BY _____	DATE _____
	PLOTTED _____		
	GRADES CHECKED _____		
	B.M. NOTED _____		
	STRUCTURE NOTATIONS CH'KD _____		
NOTE BOOK _____			
NO. _____			

MODEI: US6 PrCl -A - US6 4 [sheet]

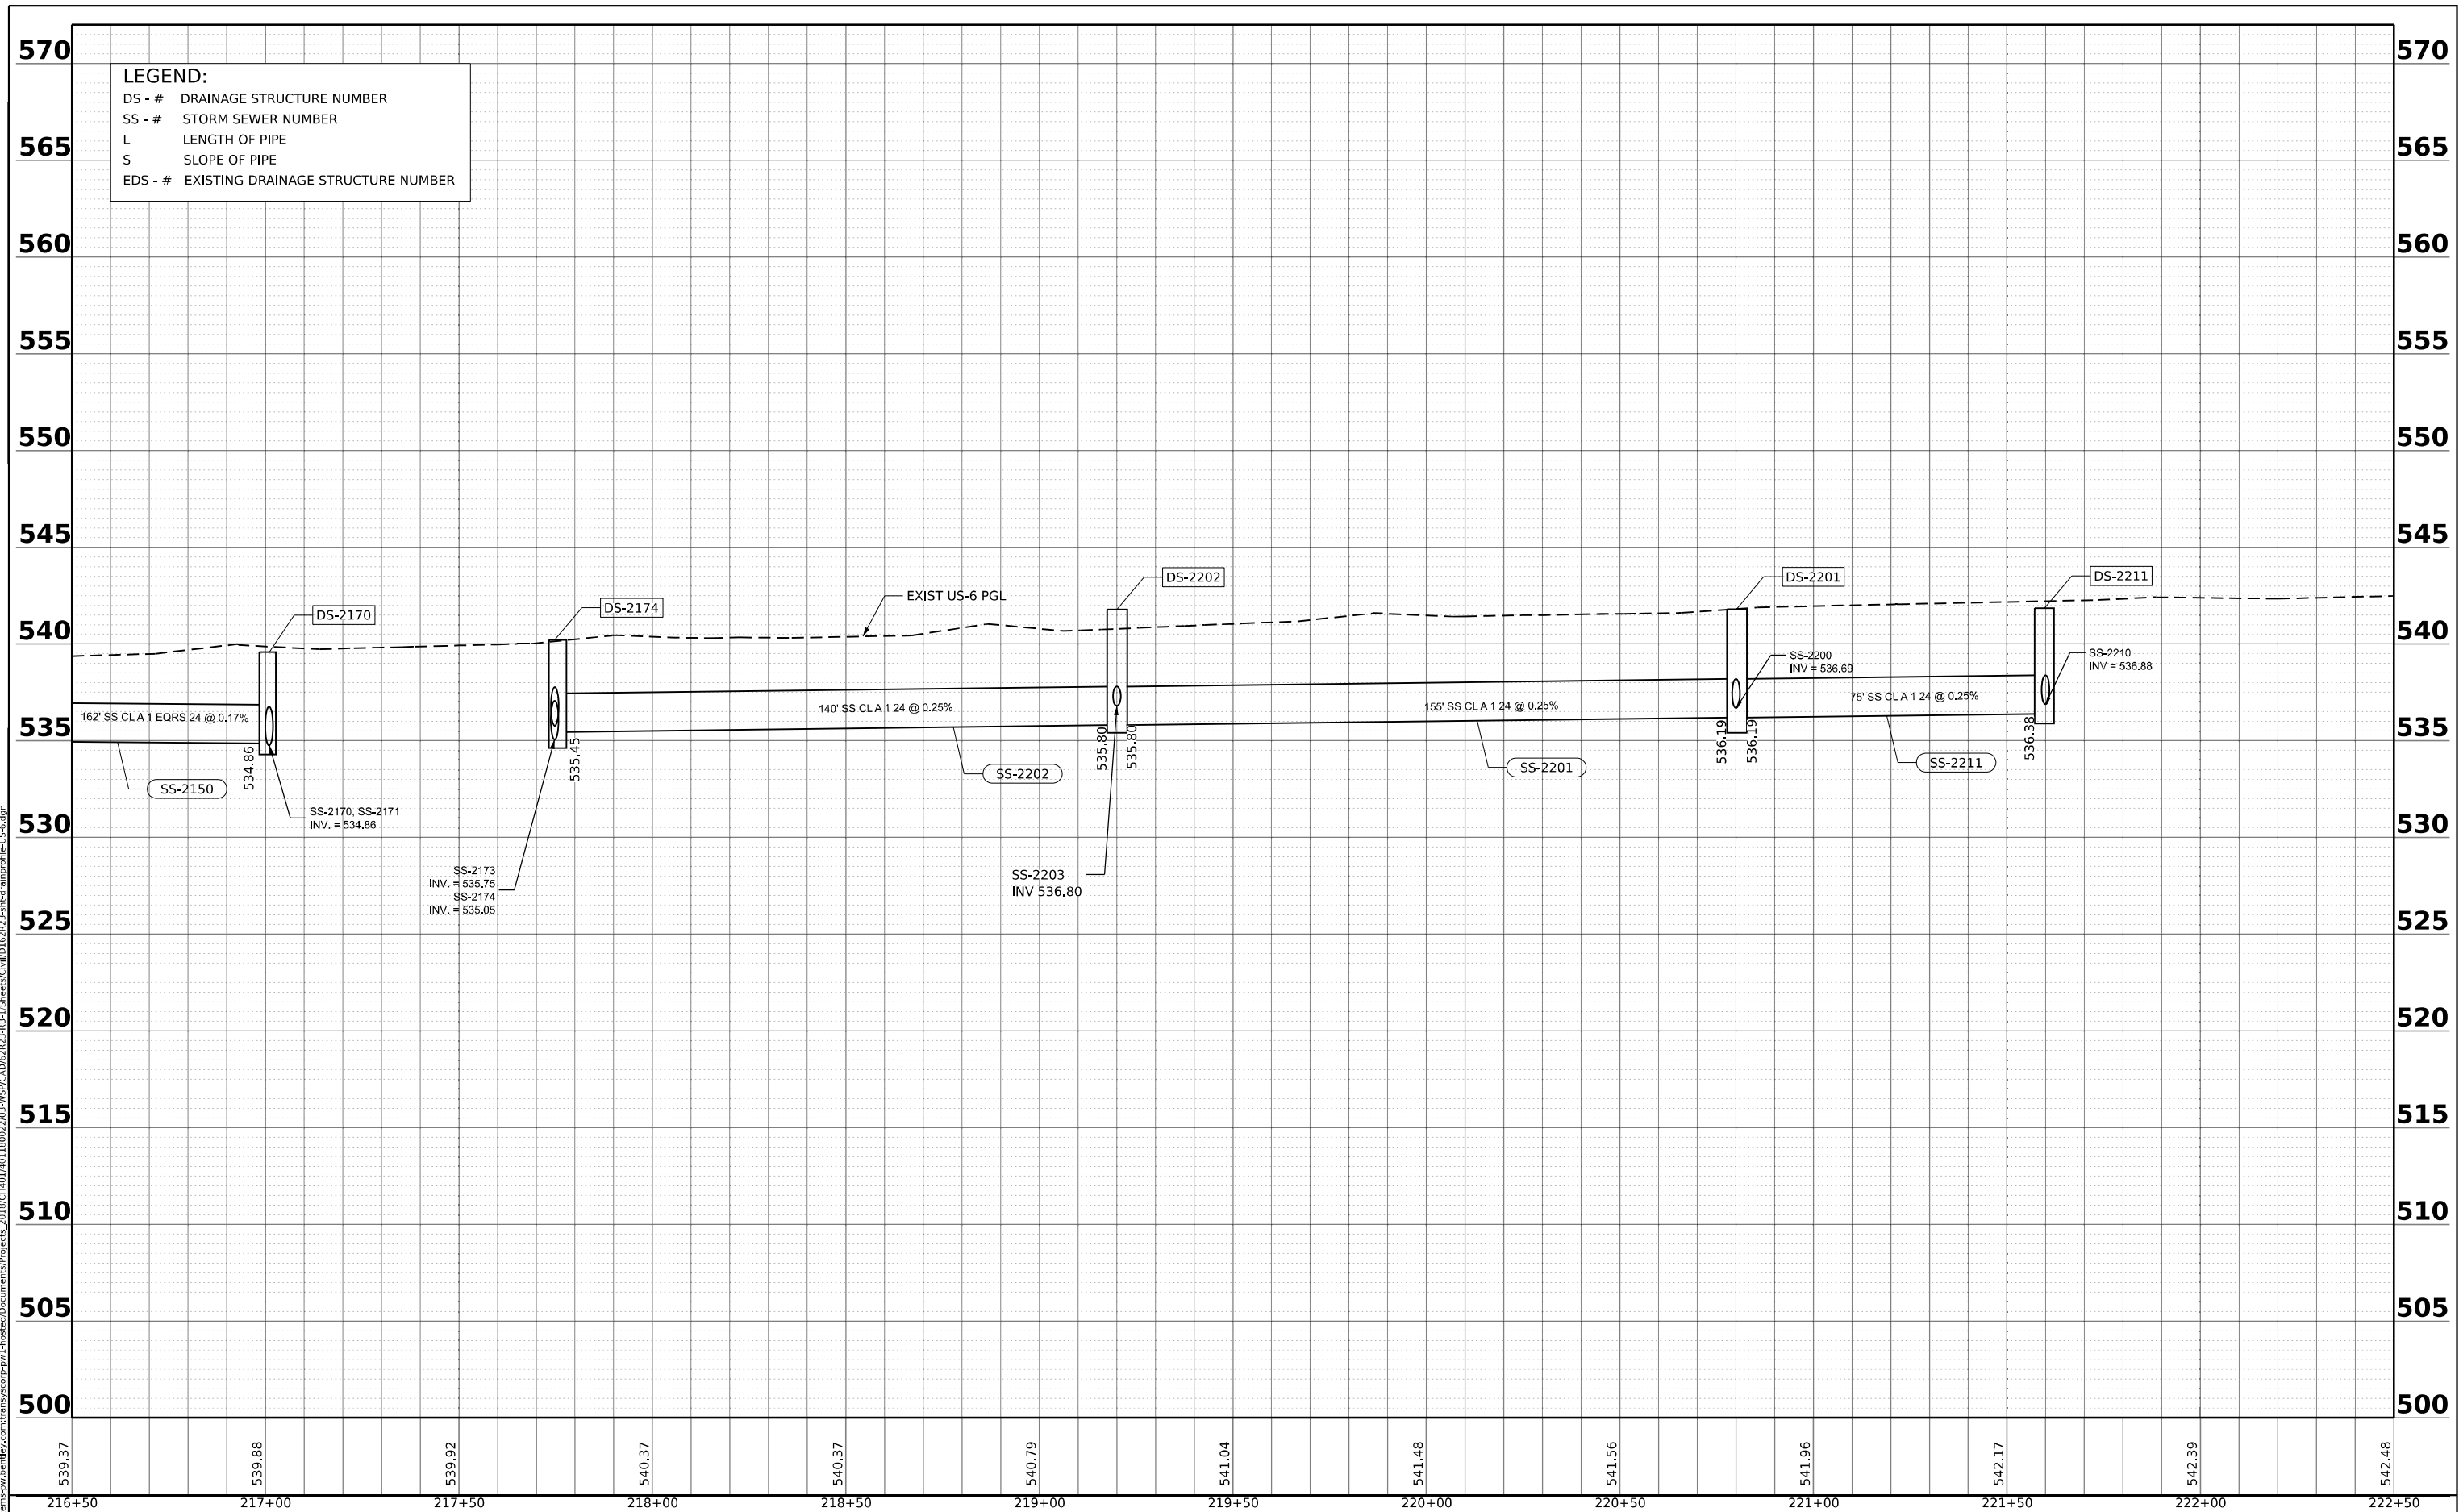


FILE NAME: 000
--

PLAN	SURVEYED	BY	DATE
NOTE BOOK NO.	PLOTTED		
	ALIGNMENT CHECKED		
	AS SHOWN		
	CADD FILE NAME		

PROFILE	SURVEYED	BY	DATE
NOTE BOOK NO.	PLOTTED		
	GRADES CHECKED		
	STRUCTURE NOTATIONS CHECKED		

MODEL US-6_PFC-L5 - US-6_5 (Sheet)
FILE NAME: p:\civil\trans\systems\pw\jenley.com\trans\scorp-pw\hosted\Documents\Projects_2018\CH401\401180022\03-WSP\CADD\621623-1-RS-1\Sheets\Civil\0162R23-shr-trainprofile-US-6.dgn

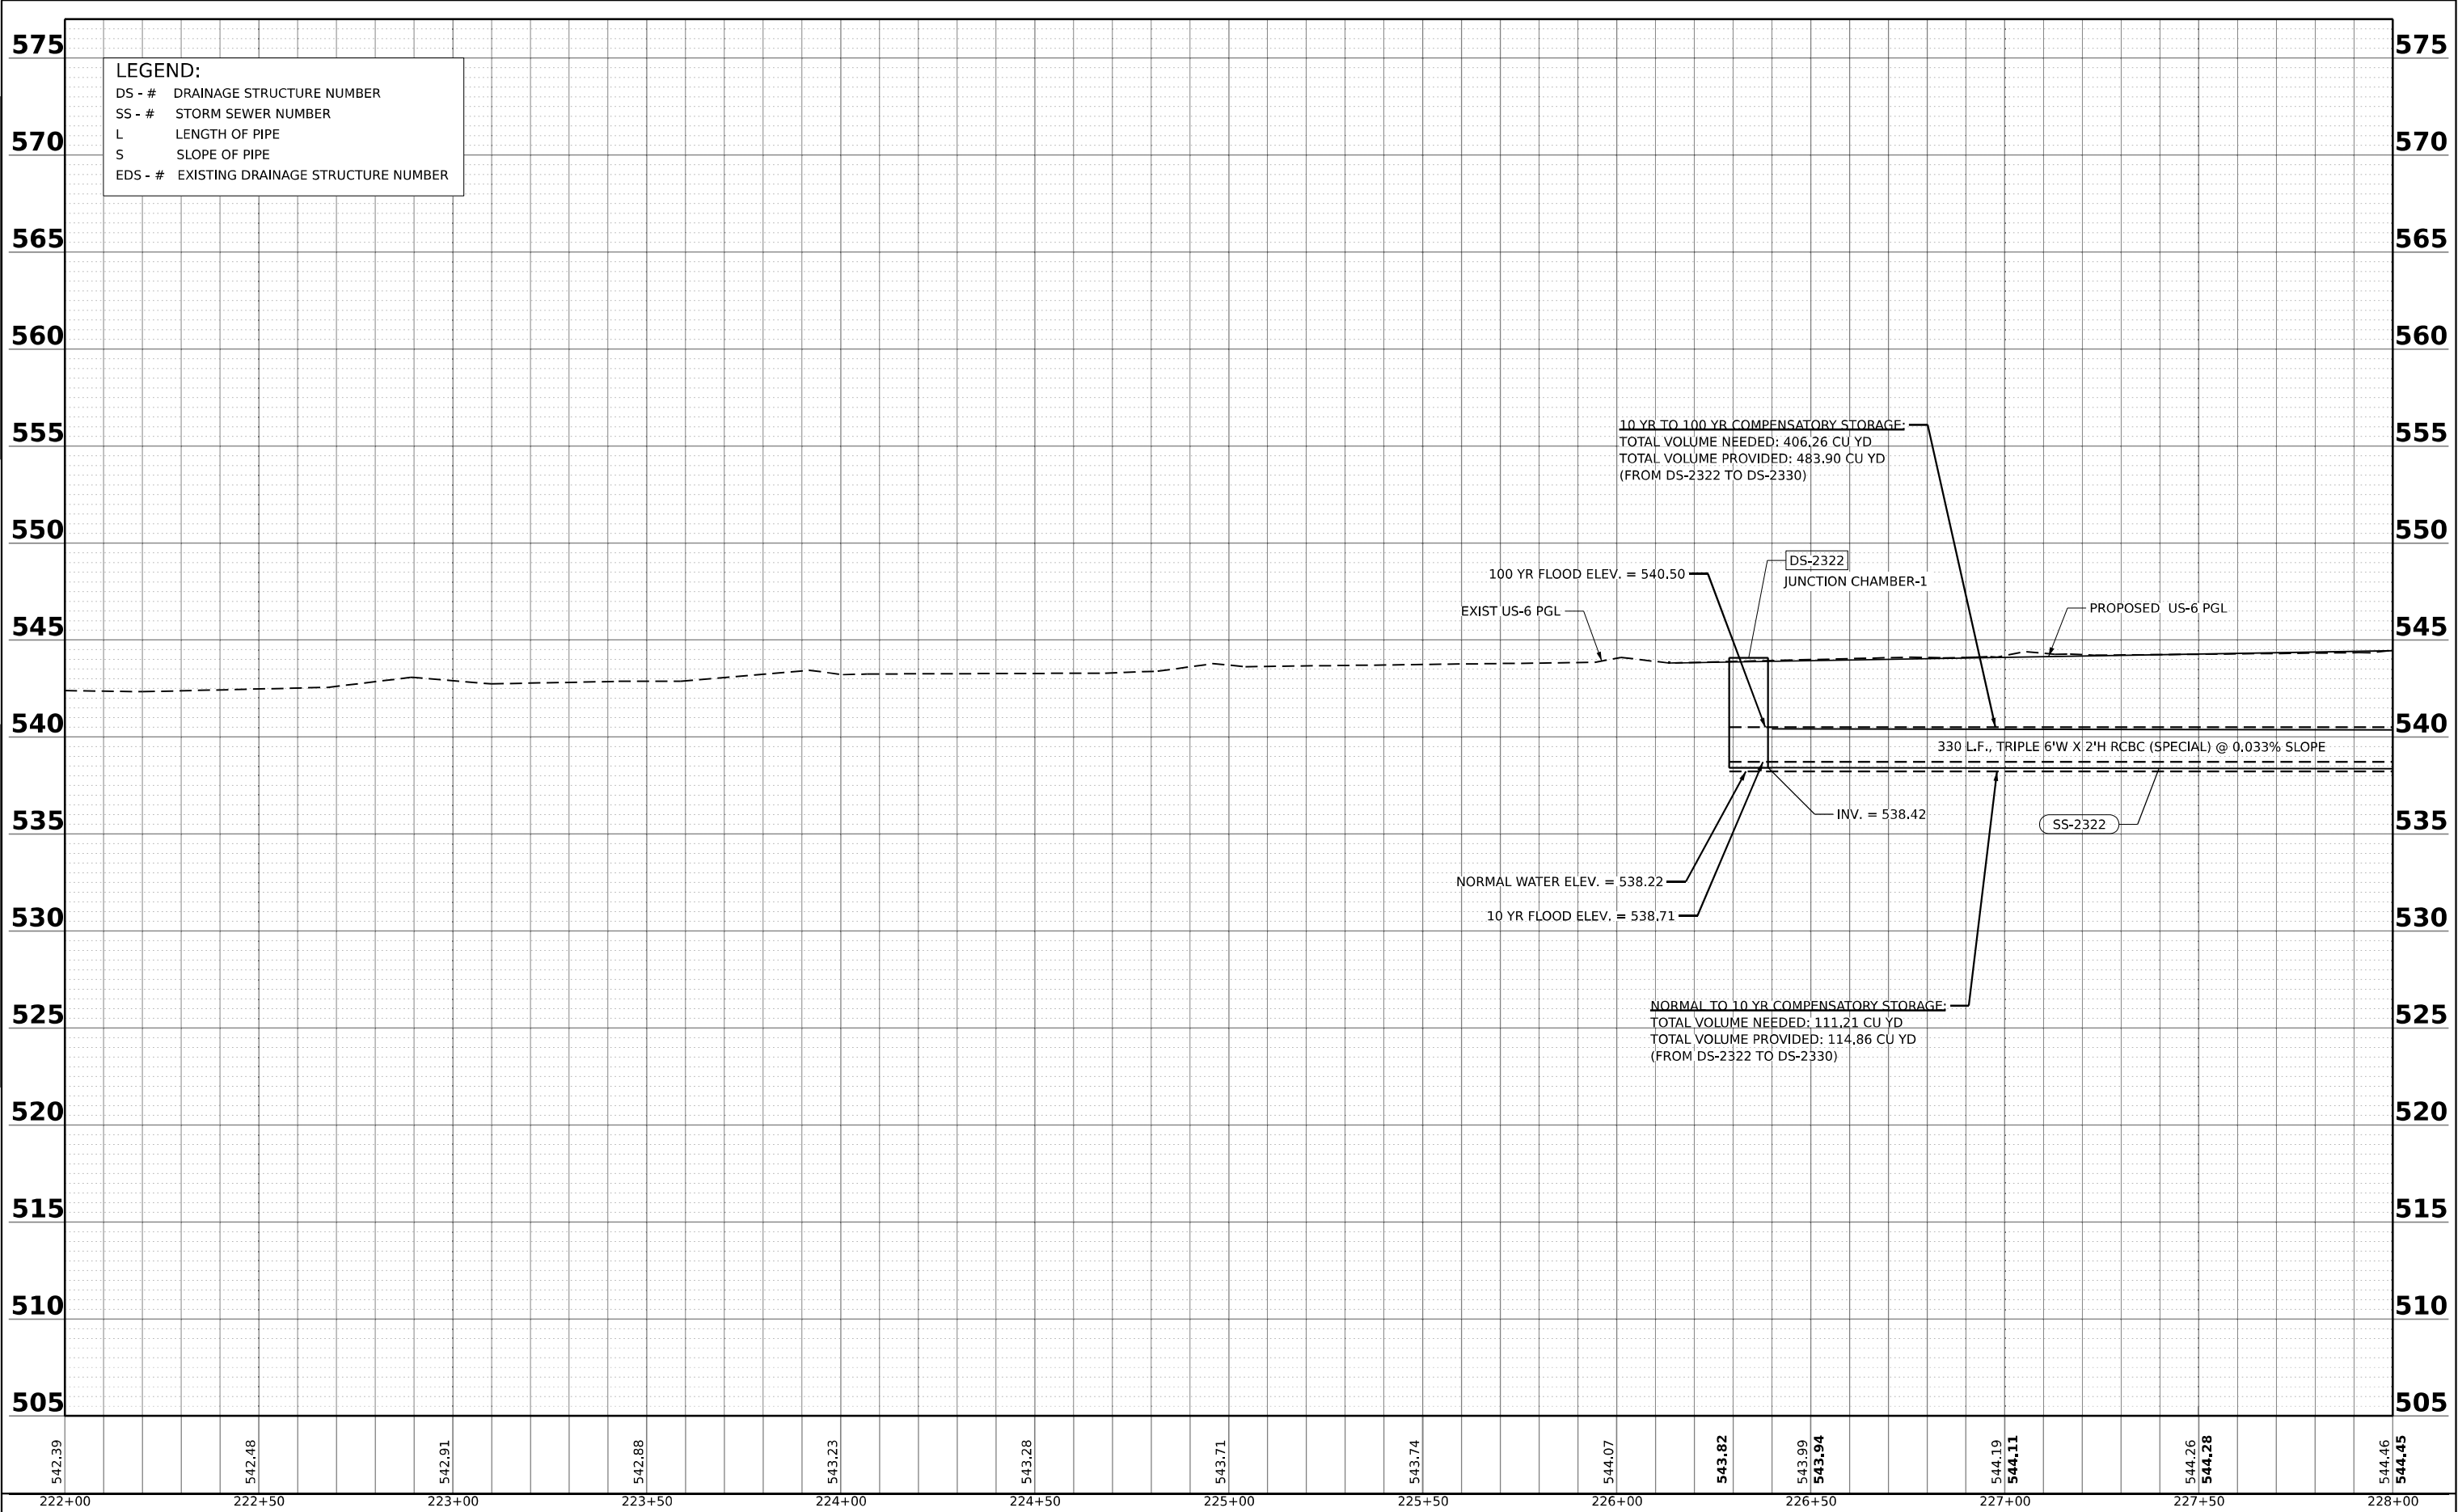


 WSP USA Inc. 30 N. LASALLE STREET SUITE 4200 CHICAGO, IL 60602 TEL: (312) 782-8150	USER NAME = USHC706648		DESIGNED - AKG	REVISED -	STATE OF ILLINOIS DEPARTMENT OF TRANSPORTATION	PROPOSED DRAINAGE AND UTILITY PROFILE					F.A.I. RTE.	SECTION		COUNTY	TOTAL SHEETS	SHEET NO.	
	DRAWN - SSM		CHECKED - KS	REVISED -		US-6					80	FAI 80 21 STRUCTURE 2		WILL	1230	352	
	PLOT SCALE = 0.16666667' / in.		DATE - 11/7/2025	REVISED -		SCALE: HORIZ: 1"=50' VERT: 1"=5'					SHEET 3	OF 4	SHEETS	STA.	TO STA.		
	PLOT DATE = 11/6/2025					CONTRACT NO. 62R23											
						ILLINOIS FED. AID PROJECT											

PLAN	NO.	NOTE BOOK	SURVEYED PLOTTED ALIGNMENT CHECKED AS SHOWN CADD FILE NAME	BY	DATE

PROFILE	NO.	NOTE BOOK	SURVEYED PLOTTED GRADES CHECKED STRUCTURE NOTATIONS CHECKED	BY	DATE

MODEL US6_PfCL6 - US6_6 (Sheet)
FILE NAME: p:\projects\transystem\benley.com\transys\corp-pw1\hosed\Documents\Projects_2018\CH401\401180022\03-WSP\CAD\62R23-RB-1\Sheets\Civil\0162R23-shr-drain\profile-US-6.dgn

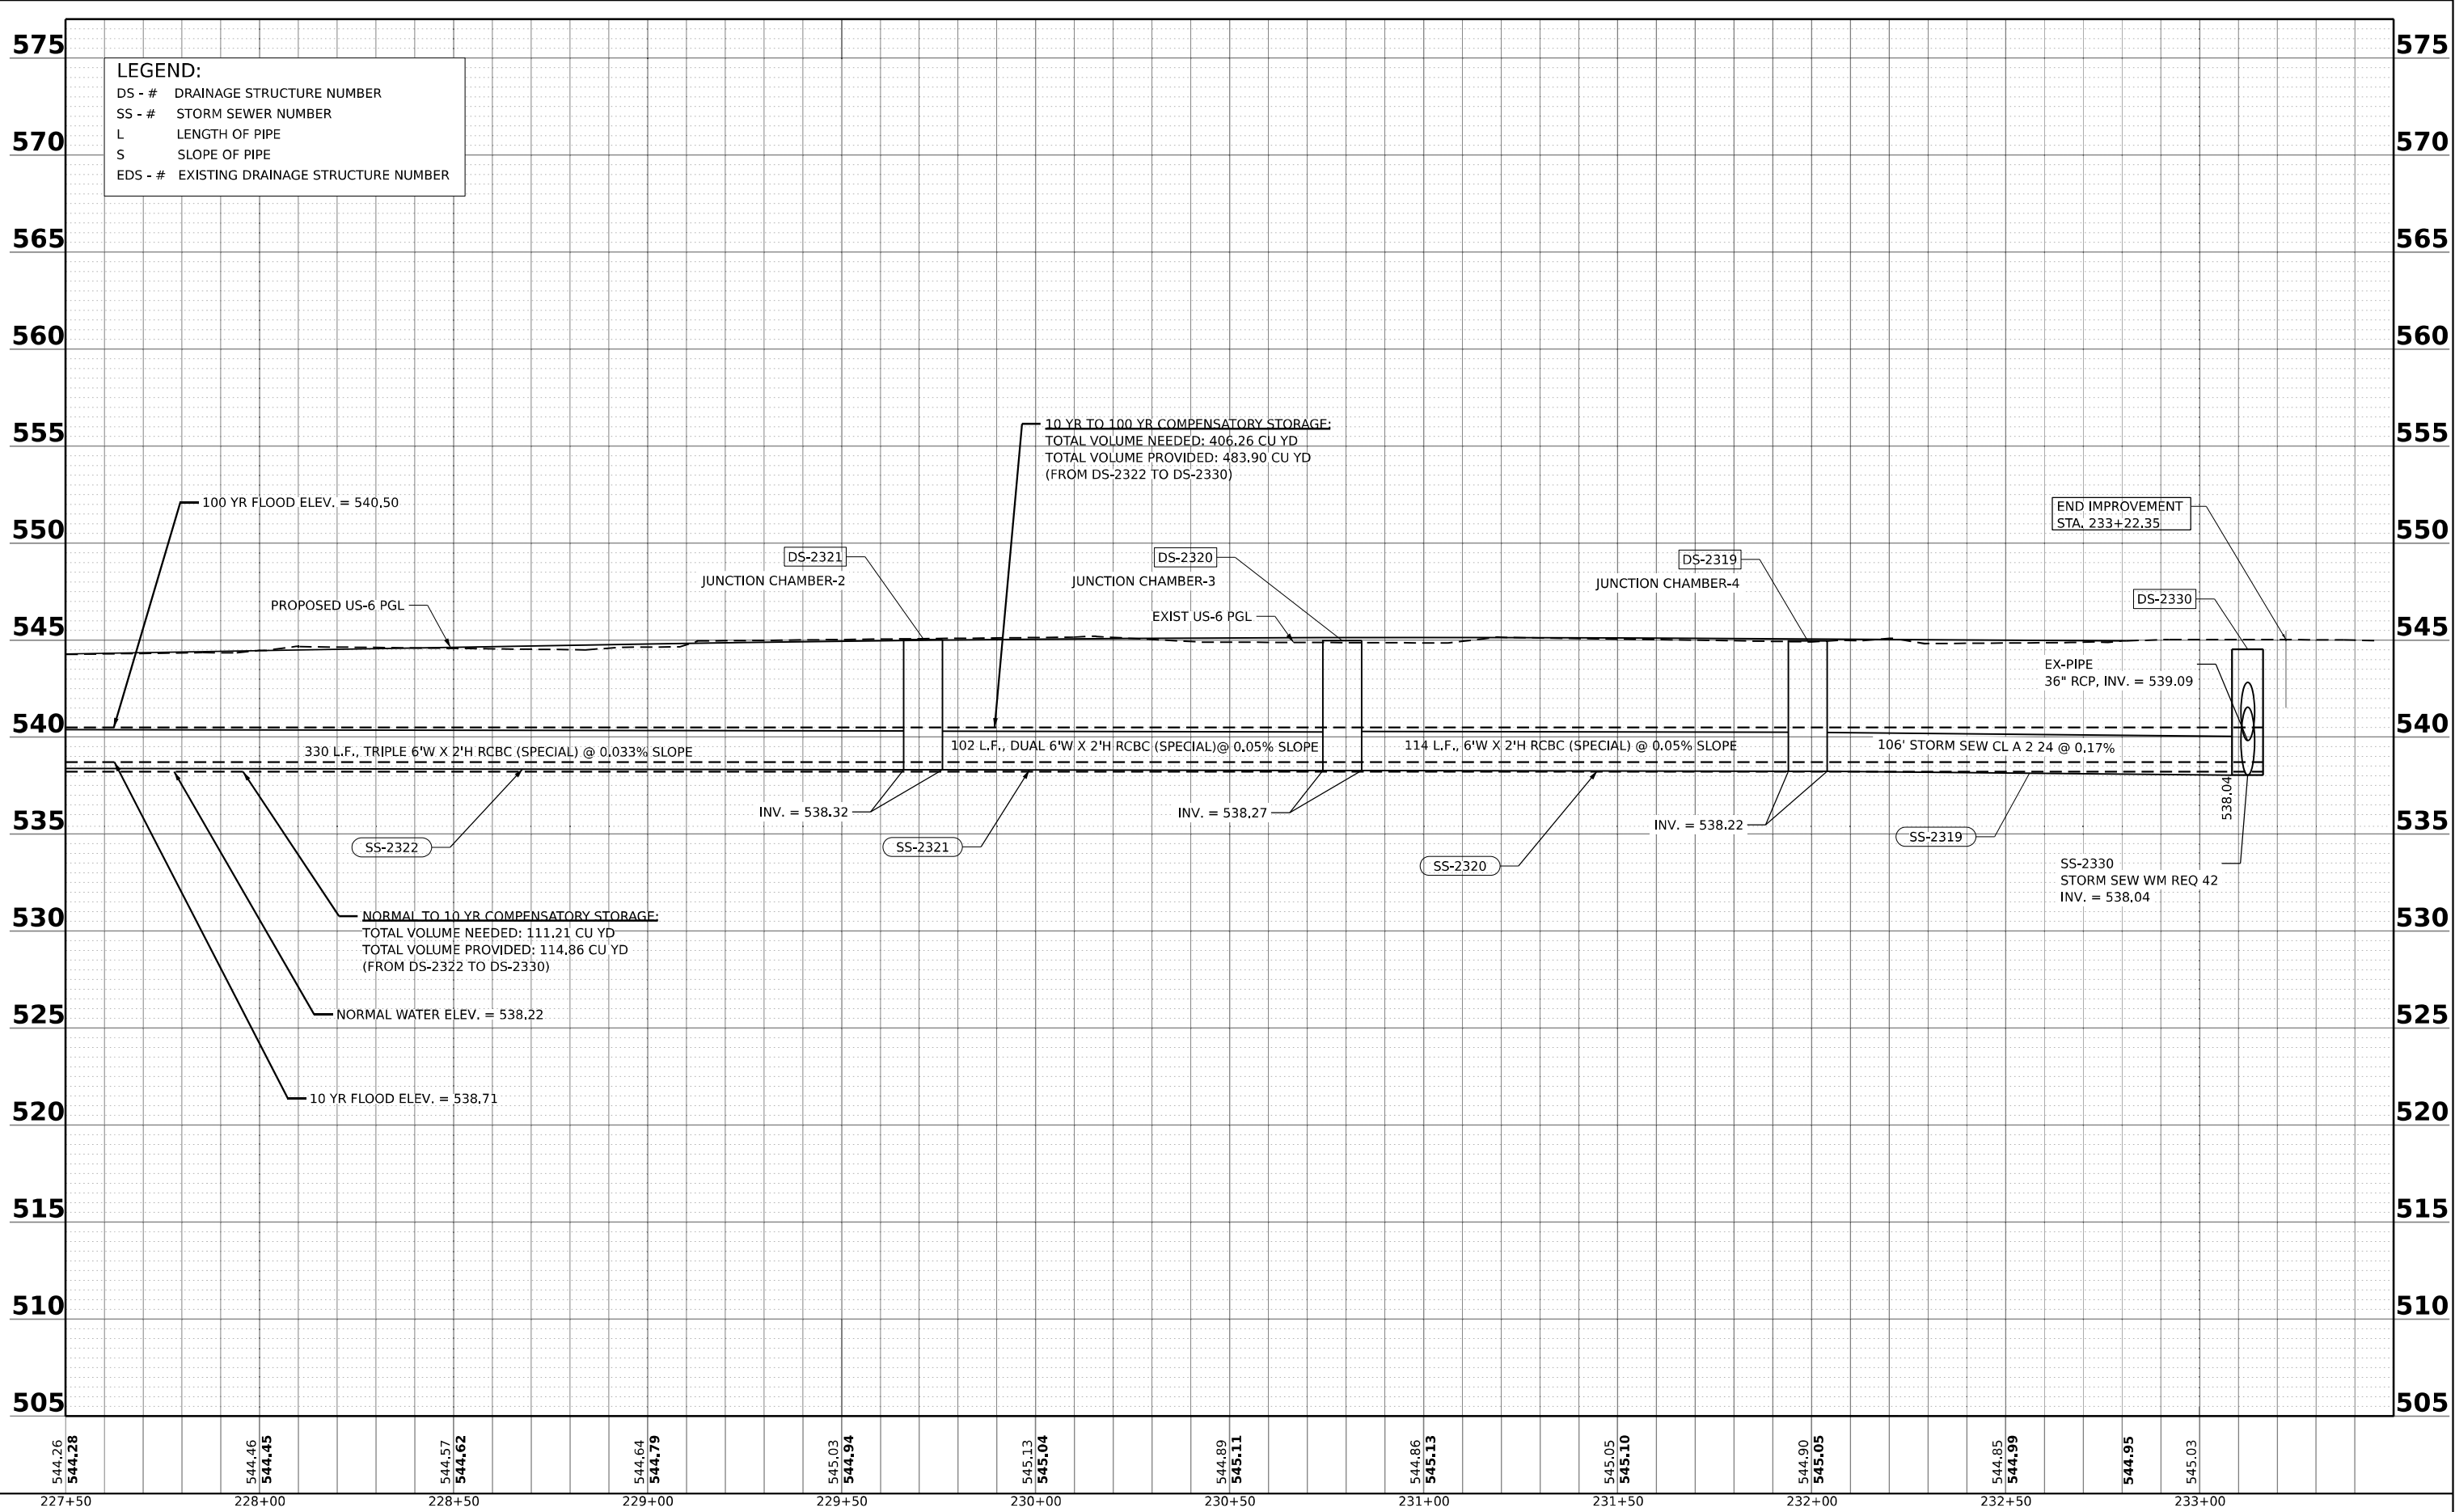

 WSP USA INC. 30 N. LASALLE STREET SUITE 4200 CHICAGO, IL 60602 TEL: (312) 782-8150	USER NAME = USHC706648		DESIGNED - AKG	REVISED -	STATE OF ILLINOIS DEPARTMENT OF TRANSPORTATION	PROPOSED DRAINAGE AND UTILITY PROFILE				F.A.I. RTE.	SECTION	COUNTY	TOTAL SHEETS	SHEET NO.
	DRAWN - SSM		CHECKED - KS	REVISED -		US-6				80	FAI 80 21 STRUCTURE 2	WILL	1230	353
	PLOT SCALE = 0.16666667 " / in.		DATE - 11/7/2025	REVISED -		SCALE: HORIZ: 1"=50' VERT: 1"=5'				CONTRACT NO. 62R23				
	PLOT DATE = 11/6/2025					SHEET 4 OF 4 SHEETS				STA.				

LEGEND

- PR. INLET

PR. CATCH BASIN

PR. MANHOLE

PR. UNDERDRAIN HEADWALL

PR. END SECTION

PR. SWALE

PR. DITCH
- PR. STORM SEWER

PR. PIPE UNDERDRAIN

PR. RIP RAP APRON

XXXX

PR. STRUCTURE

XXXX

PR. PIPE

UC

UTILITY CROSSING

NOTE: * FLAT SLAB TOP

*DS-1040
STA. 104+30, 4.4' LT
MAN TA 4 DIA T1F CL
RIM = 519.00
INV. = 515.61 (N)
INV. = 515.71 (W)
EX INV. = 515.61 (15" S)

DS-1041
STA. 104+30, 45.8' LT
CONC ES 542001 15 1:3
INV. = 516.00' (E)

*DS-1042
STA. 104+80, 10.8' LT
CB TA 4 DIA T11 F&G
RIM = 518.62
INV. = 515.75 (N, E)

*DS-1043
STA. 104+80, 12.1' RT
CB TA 5 DIA T1F OL
RIM = 518.64
INV. = 515.77 (W,N)

*DS-1045
STA. 104+80, 4.4' LT
CB TA 5 DIA T1F CL
RIM = 518.74
INV. = 515.73 (W, E, S)

*DS-1050
STA. 105+34, 18.6' RT
MAN TA 5 DIA T1F CL
RIM = 519.03
INV. = 515.93 (W,N,S)

DS-1052
STA. 105+34, 12.6' RT
CB TC 2 DIA T11 F&G
RIM = 518.45
INV. = 515.95 (E)

DS-1053
STA. 105+34, 13.4' LT
CB TC 2 DIA T11 F&G
RIM = 518.45
INV. = 516.00 (S)

SS-1041
STORM SEW WM REQ 15
32' @ 1.00%
TBF = 0.4 CY

SS-1042
STORM SEW CL A 5 12
3' @ 0.67%
TBF = 0.3 CY

SS-1043
STORM SEW CL A 1 EQRS 15
12' @ 0.33%
TBF = 0.8 CY

SS-1045
STORM SEW CL A 1 EQRS 18
45' @ 0.27%
TBF = 4.1 CY

SS-1050
STORM SEW CL A 1 EQRS 15
50' @ 0.32%
TBF = 0 CY

SS-1052
STORM SEW CL A 1 12
1.8' @ 0.6%
TBF = 0 CY

SS-1053
STORM SEW WM REQ 12
50' @ 0.50%
TBF = 0 CY

NOTES:

- FOR PLACEMENT OF DRAINAGE STRUCTURE, SEE SHEET 383
- FOR RIPRAP DETAILS, SEE SHEET 384
- UC: PROPOSED STORM SEWER CONFLICT WITH PROPOSED CITY OF JOLIET UTILITIES; REFER TO JOLIET DRAINAGE AND UTILITY PLANS

RIVER ST UTILITY CROSSING TABLE								
CROSSING NUMBER	LOCATION		PIPE INFORMATION			INVERT ELEVATION	OUTER ELEVATION	CLEARANCE (FEET)
	STATION	OFFSET	STATUS	SIZE	TYPE			
	UC-8	104+30	24.2 LT	PR	15"			
			PR	8"	GAS	512.27	512.94	
	WSP INC. 29 N LA SALLE STREET SUITE 4200 CHICAGO, IL 60662 TEL: (312) 782-3350		USER NAME = USHC706648			DESIGNED - AKG		REVISED -
						DRAWN - SSM		REVISED -
			PLOT SCALE = 40,000 ' / in.			CHECKED - KS		REVISED -
			PLOT DATE = 11/6/2025			DATE - 11/7/2025		REVISED -



STATE OF ILLINOIS
DEPARTMENT OF TRANSPORTATION


PROPOSED DRAINAGE AND UTILITY PLAN
RIVER STREET

SCALE: 1"=20' SHEET 1 OF 2 SHEETS STA. TO STA.


F.A.I. RTE.	SECTION	COUNTY	TOTAL SHEETS	SHEET NO.
80	FAI 80 21 STRUCTURE 2	WILL	1230	354
CONTRACT NO. 62R23				
ILLINOIS FED. AID PROJECT				

 KEY PLAN

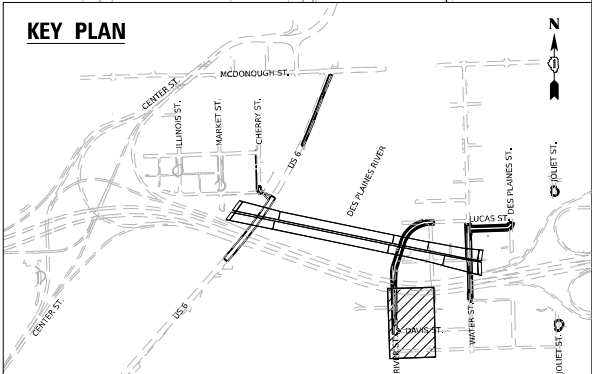

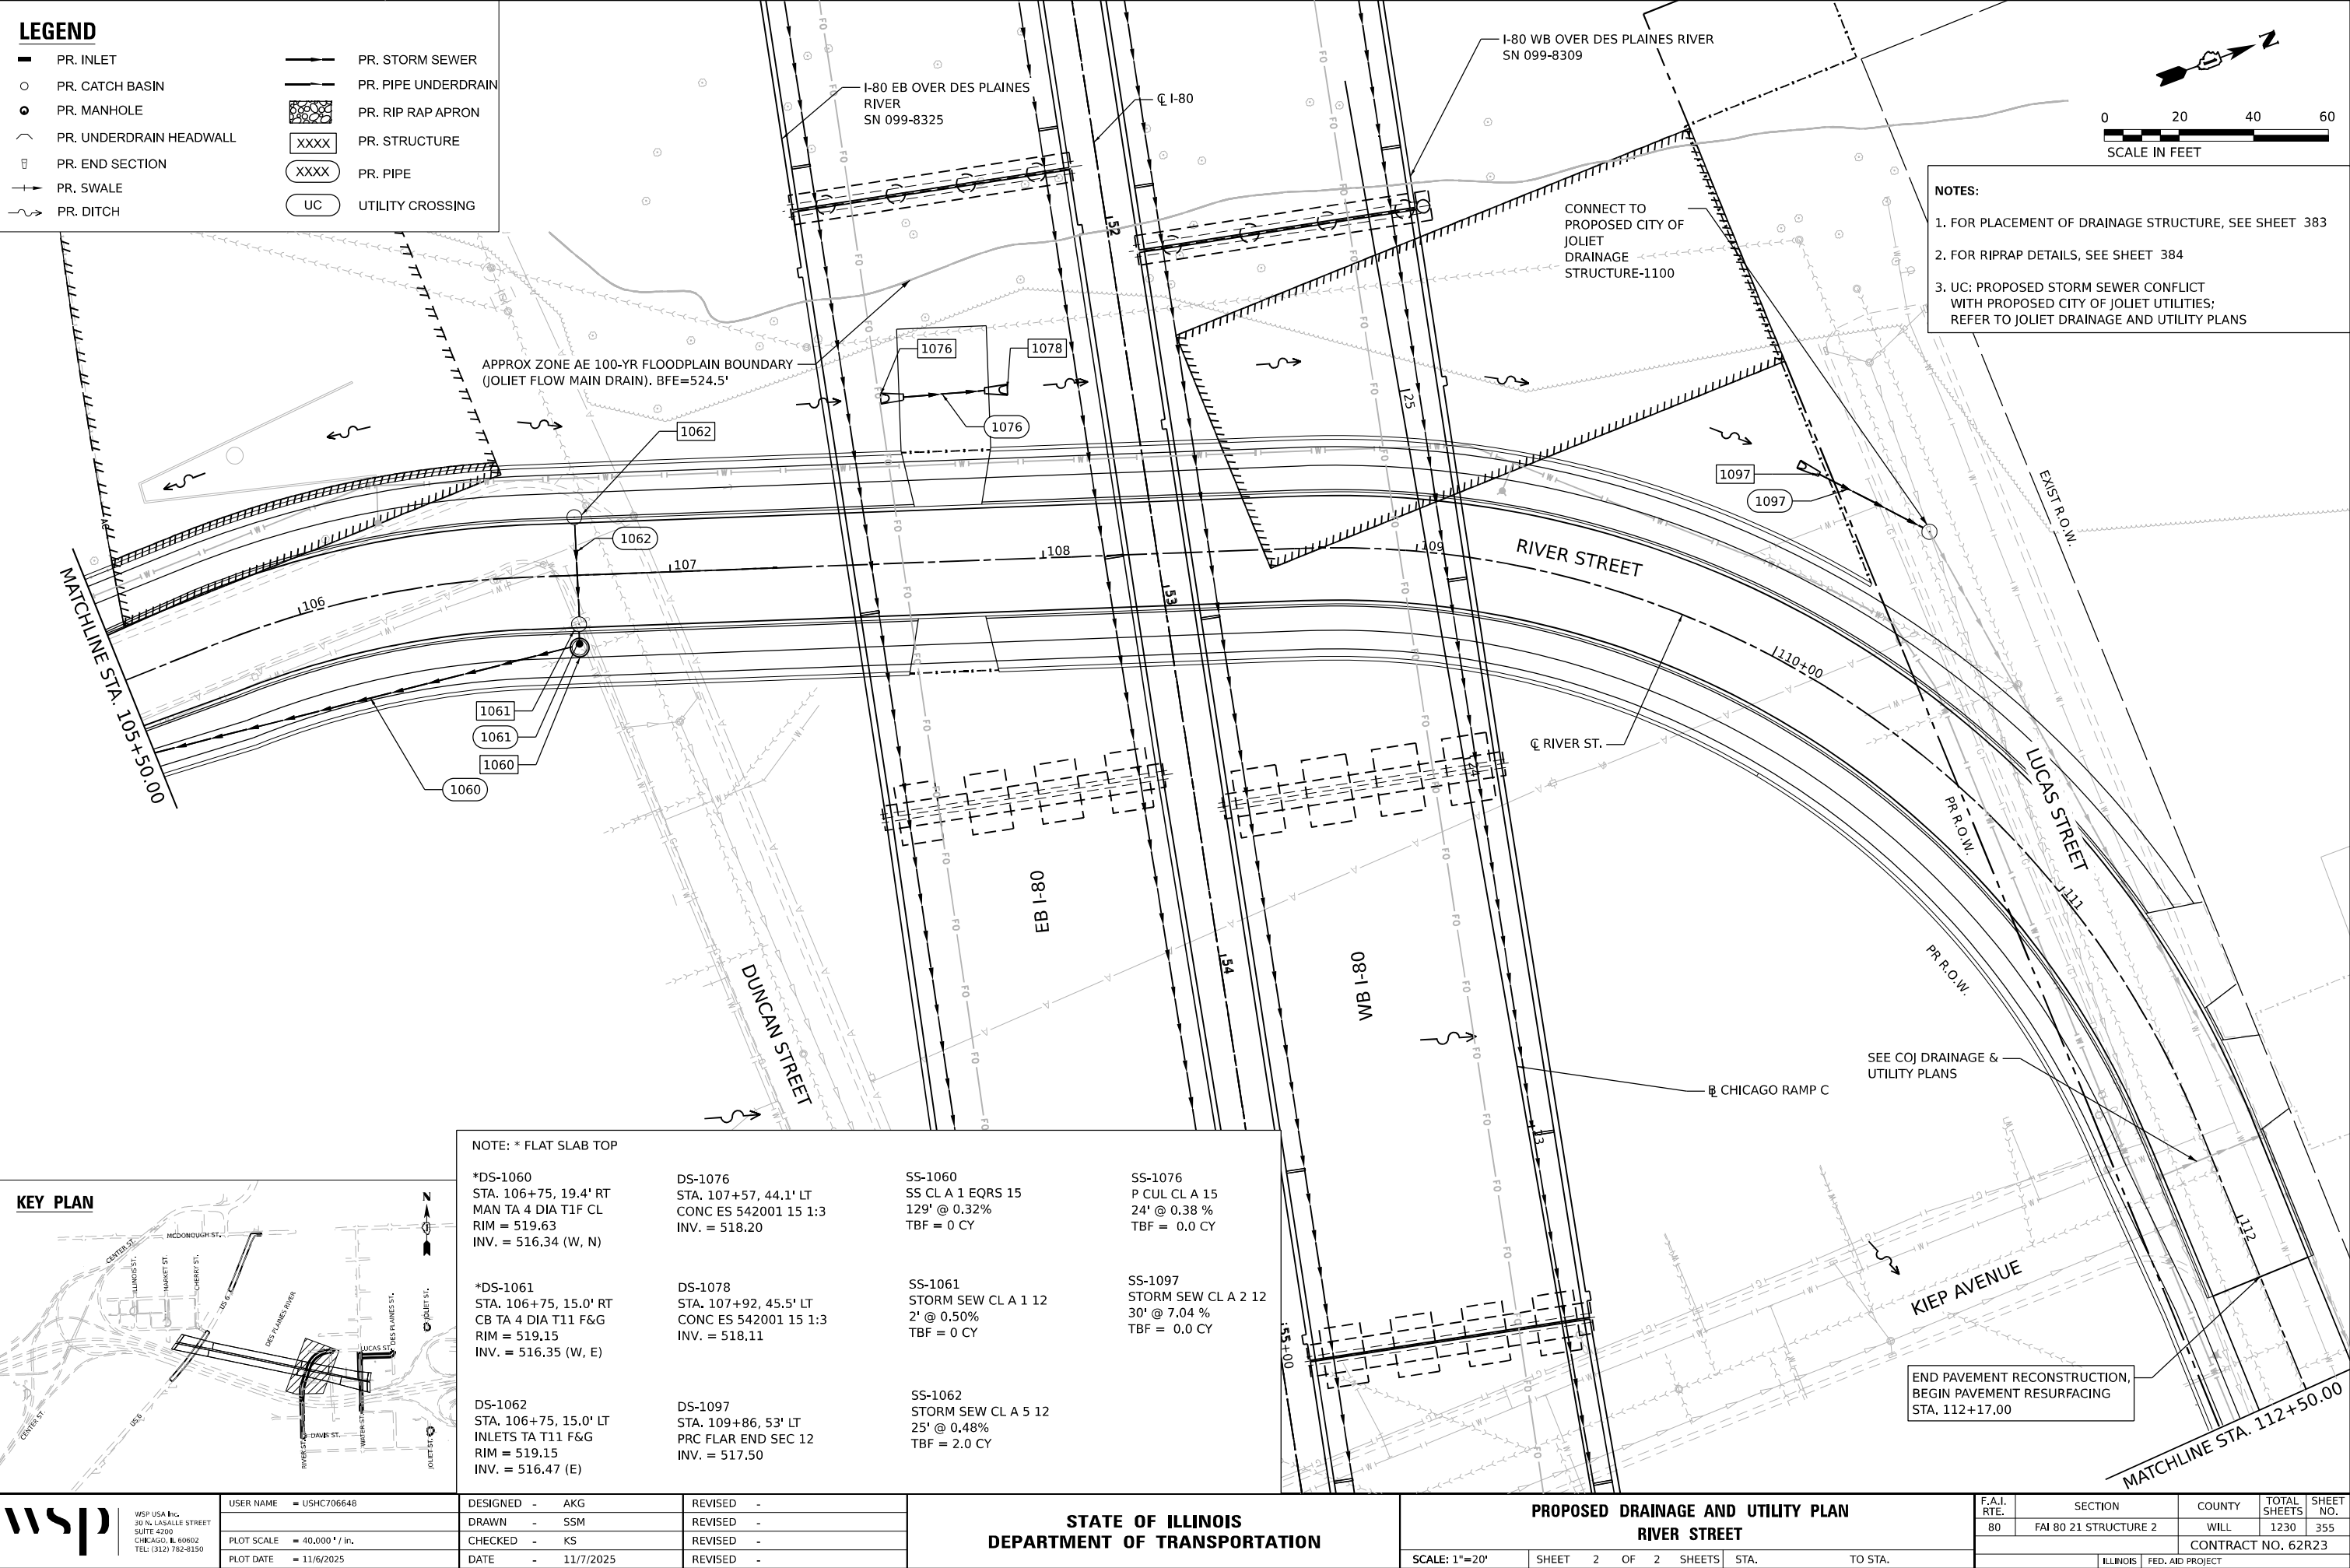

MODEL: P:\C:\RiverStreet-3 - River-1 (Sheet)
FILE NAME: p:\trans\trans\ppl\boxed\Documents\projects_2018\C4001\401180022\03\WSP\CD\62023_RB-1_Sheets\Civil\DR23-shr-drain\ppl\3.dgn

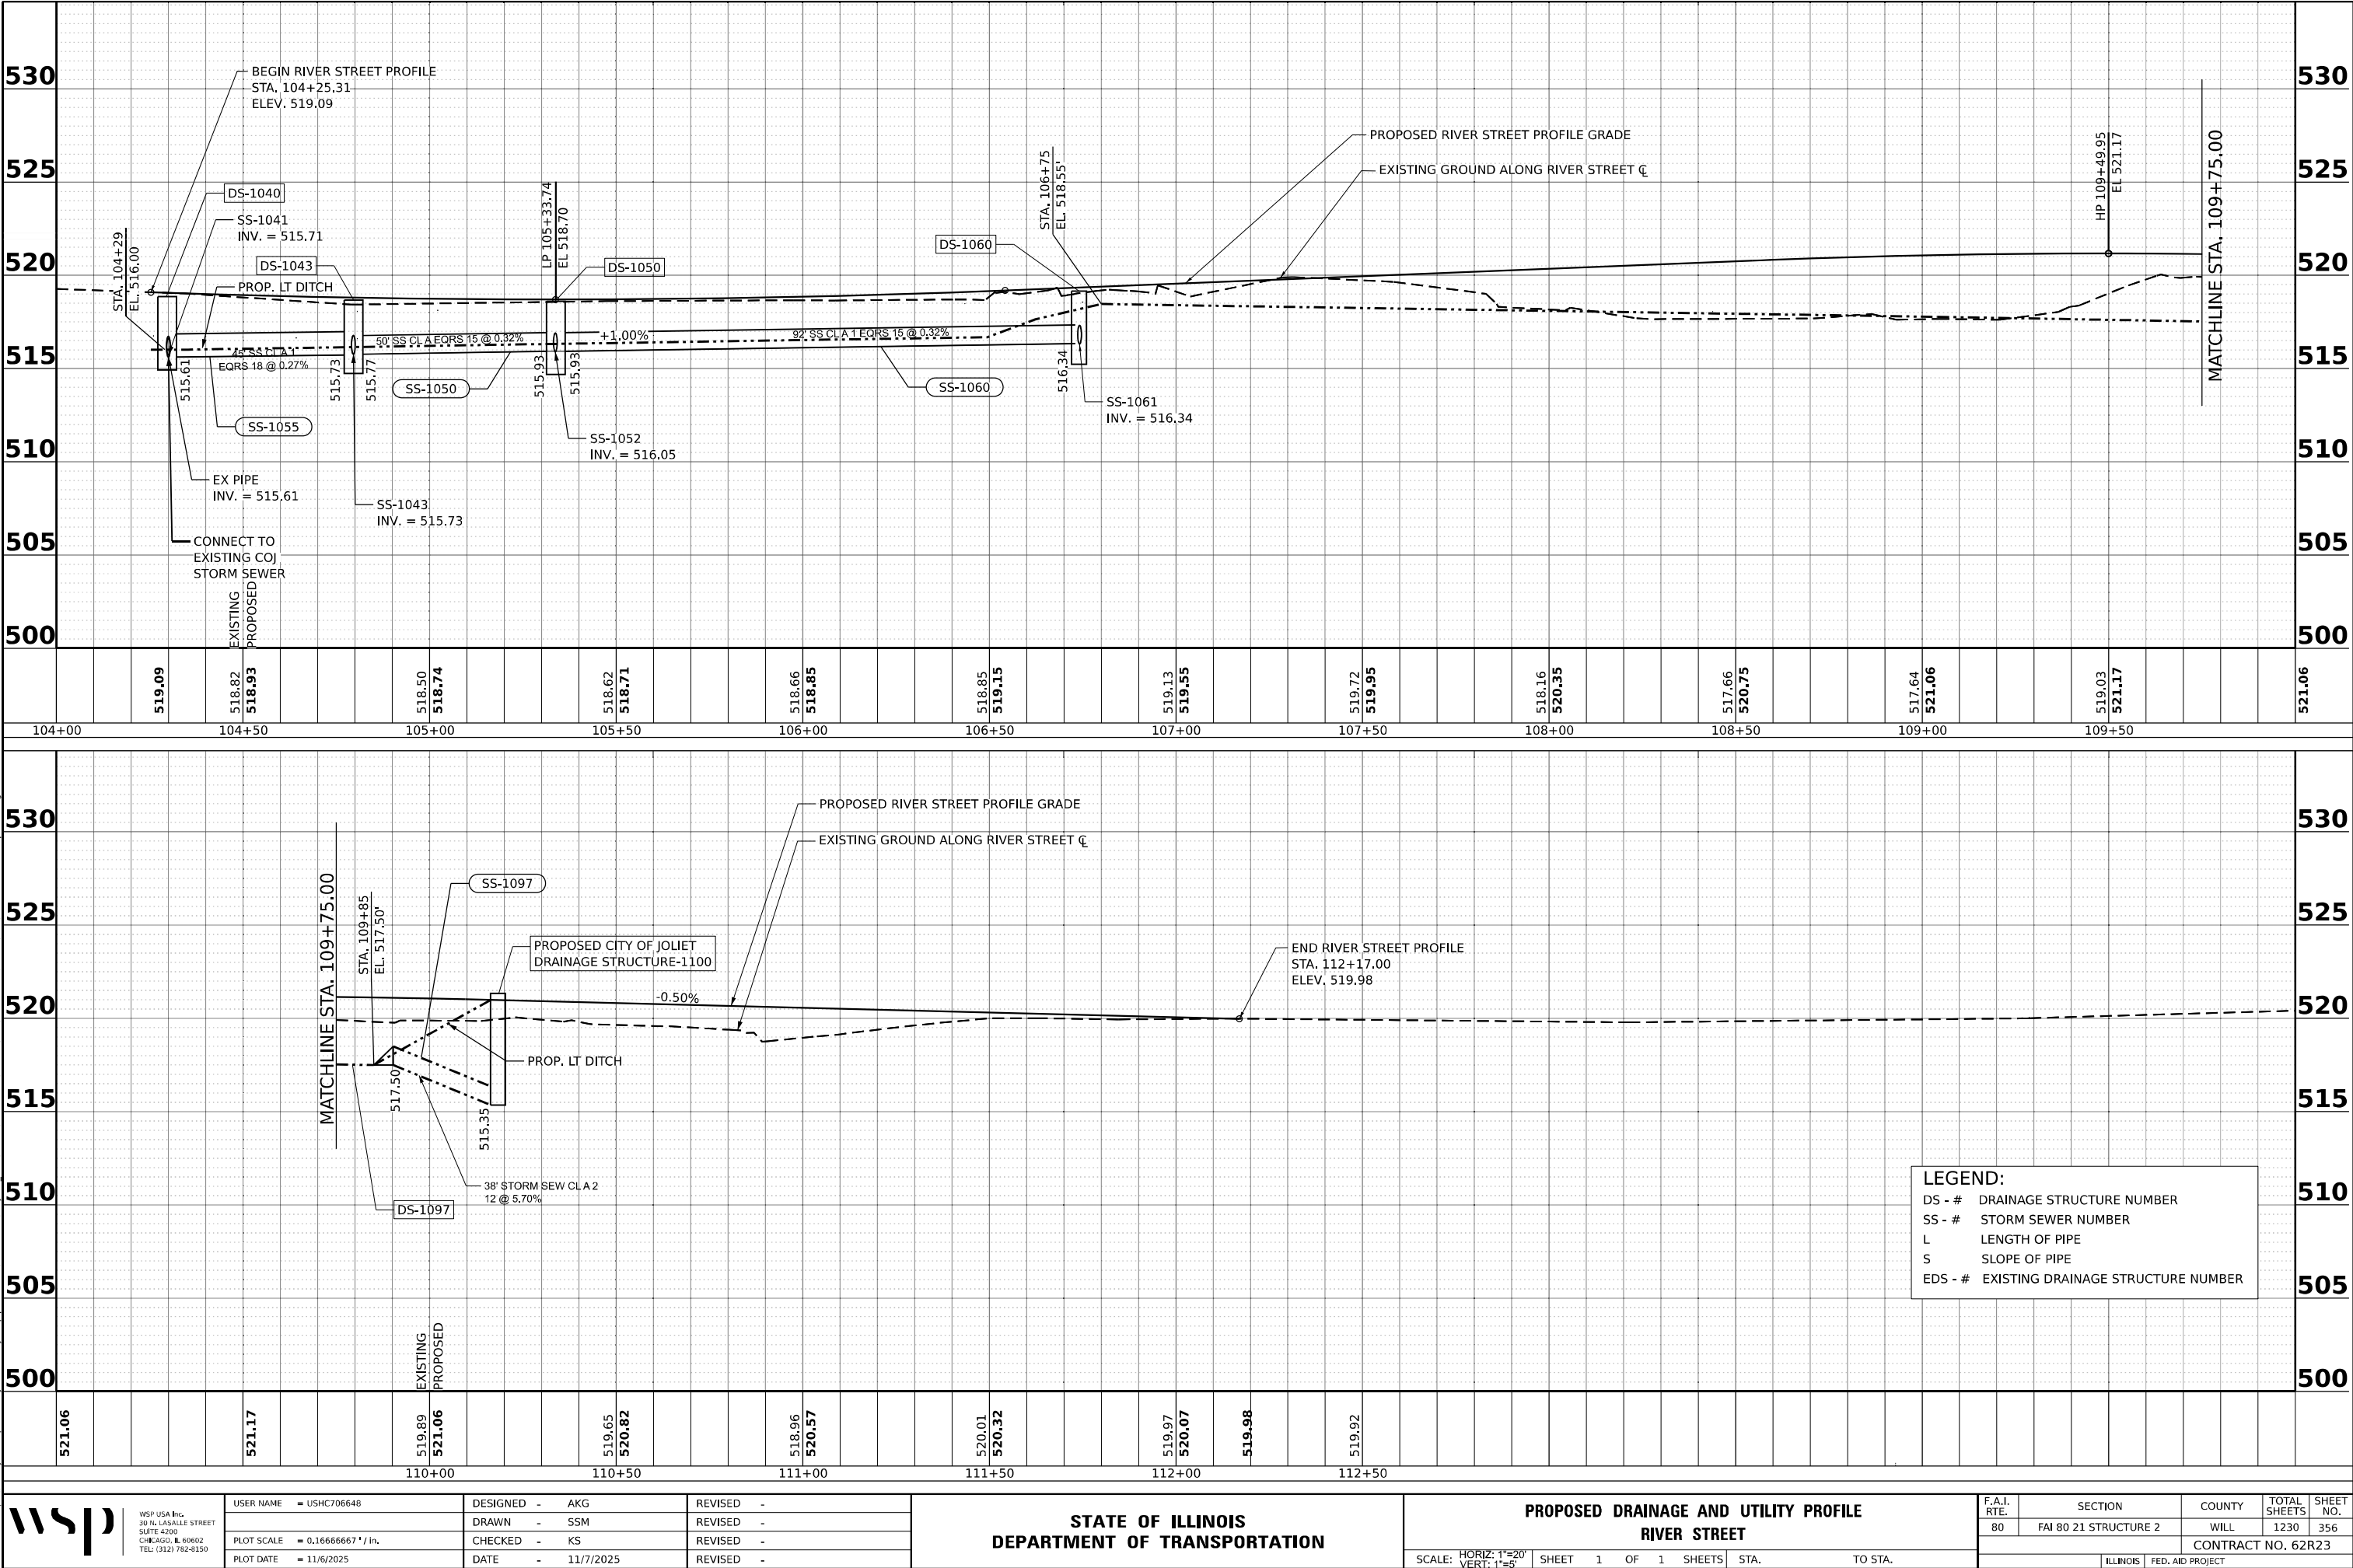

WSP USA INC.
30 N. LA SALLE STREET
SUITE 4200
CHICAGO, IL 60602
TEL: (312) 782-8150

USER NAME	= USHC706648
PLOT SCALE	= 0.16666667' / in.
PLOT DATE	= 11/6/2025

DESIGNED -	AKG
DRAWN -	SMM
CHECKED -	KS
DATE -	11/7/2025

REVISED -	
REVISED -	
REVISED -	
REVISED -	

STATE OF ILLINOIS
DEPARTMENT OF TRANSPORTATION

PROPOSED DRAINAGE AND UTILITY PROFILE
RIVER STREET

SCALE: HORIZ: 1"=20'
VERT: 1"=5'
SHEET 1 OF 1 SHEETS
STA. TO STA.

F.A.I. RTE.	SECTION	COUNTY	TOTAL SHEETS	SHEET NO.
80	FAI 80 21 STRUCTURE 2	WILL	1230	356
CONTRACT NO. 62R23				
ILLINOIS FED. AID PROJECT				

LEGEND

- PR. INLET

PR. CATCH BASIN

PR. MANHOLE

PR. UNDERDRAIN HEADWALL

PR. END SECTION

PR. SWALE

PR. DITCH
- PR. STORM SEWER

PR. PIPE UNDERDRAIN

PR. RIP RAP APRON

XXXX

PR. STRUCTURE

XXXX

PR. PIPE

UC

UTILITY CROSSING

- *DS-4000

STA. 400+70, 15.6 RT

CB TA 4 DIA T11 F&G

RIM = 519.93

INV. = 517.17 (E, N)

DS-4001

STA. 400+70, 15.0' LT

INLETS TA T11 F&G

RIM = 520.15

INV. = 517.42 (S)

DS-4021

STA. 402+50, 15.0' LT

INLETS TA T11 F&G

RIM = 523.36

INV. = 520.01 (S)

SS-4000

SS CL A 1 EQRS 15

24' @ 0.33%

TBF = 1.6 CY

SS-4010

STORM SEW CL A 2 15

30' @ 0.33%

TBF = 0.0 CY

SS-4021

STORM SEW WM REQ 12

25' @ 1.03%

TBF = 15.0 CY
- *DS-4010

STA. 400+98, 15.6' RT

CB TA 4 DIA T11 F&G

RIM = 520.08

INV. = 517.09 (W)

INV. = 517.09 (E)

INV. = 517.09 (S)

*DS-4020

STA. 402+50, 15.6' RT

CB TA 4 DIA T11 F&G

RIM = 523.36

INV. = 517.58 (W)

INV. = 519.76 (N)

*DS-1030

STA. 113+59, 49.2' RT

CB TA 4 DIA T8G

RIM = 518.00

INV. = 513.84 (N)

SS-4001

STORM SEW WM REQ 12

27' @ 0.94%

TBF = 1.9 CY

SS-4020

STORM SEW CL A 1 15

149' @ 0.33%

TBF = 36.1 CY



SS-1030

STORM SEW WM REQ 12

31' @ 1.21%


TBF = 0.0 CY

NOTE: * FLAT SLAB TOP

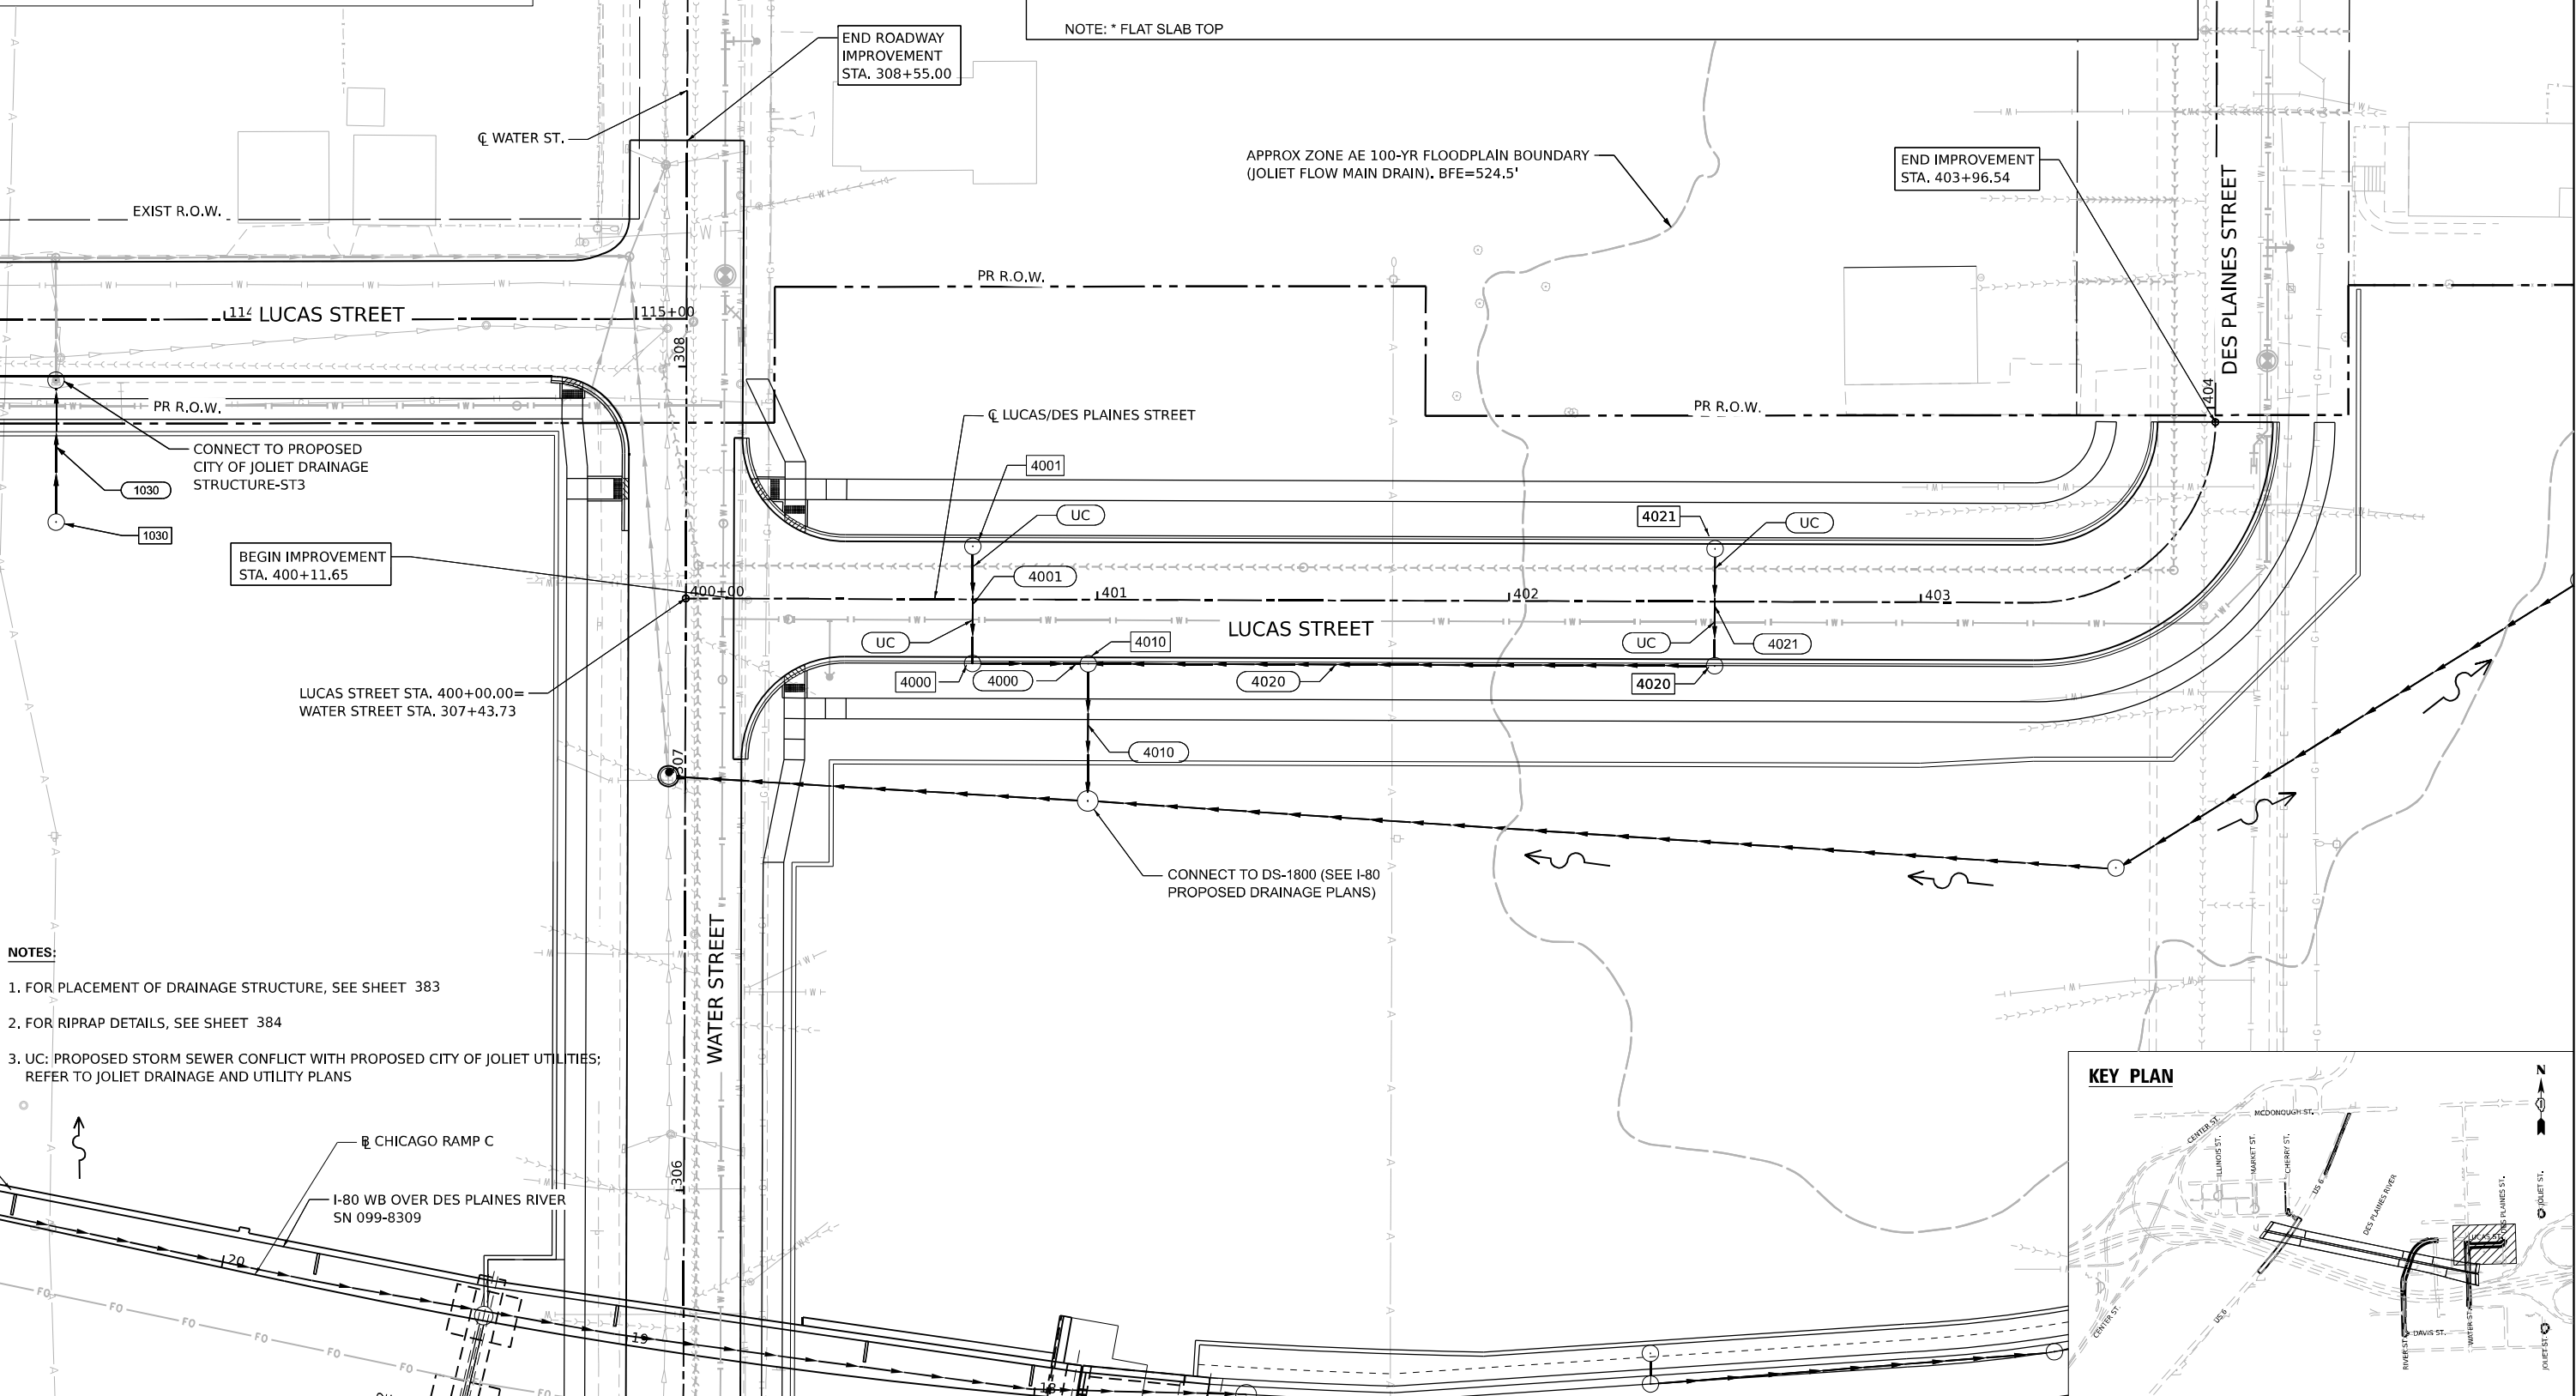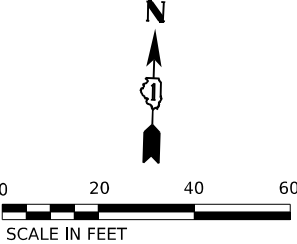


- NOTES:
1. FOR PLACEMENT OF DRAINAGE STRUCTURE, SEE SHEET 383
 2. FOR RIPRAP DETAILS, SEE SHEET 384
 3. UC: PROPOSED STORM SEWER CONFLICT WITH PROPOSED CITY OF JOLIET UTILITIES; REFER TO JOLIET DRAINAGE AND UTILITY PLANS

KEY PLAN



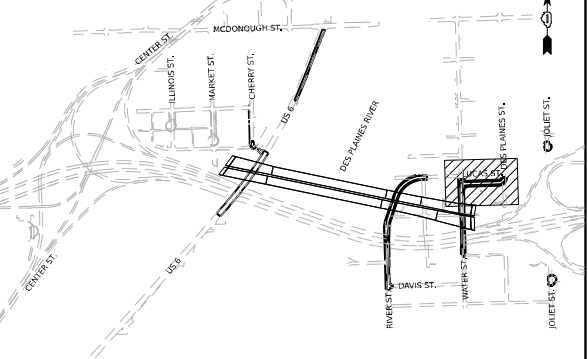


 WSP USA INC. 30 N. LASALLE STREET SUITE 4200 CHICAGO, IL 60602 TEL: (312) 782-8150	USER NAME = USHC706648		DESIGNED - AKG	REVISED -	STATE OF ILLINOIS DEPARTMENT OF TRANSPORTATION	PROPOSED DRAINAGE AND UTILITY PLAN LUCAS STREET			F.A.I. RTE.	SECTION	COUNTY	TOTAL SHEETS	SHEET NO.
	DRAWN - SSM		REVIS	REVISED -					80	FAI 80 21 STRUCTURE 2	WILL	1230	357
	PLOT SCALE = 40,000' / in.		CHECKED - KS	REVISED -		CONTRACT NO. 62R23							
	PLOT DATE = 11/6/2025		DATE - 11/7/2025	REVISED -		ILLINOIS FED. AID PROJECT							
						SCALE: 1"=20'	SHEET 1 OF 1 SHEETS	STA.	TO STA.				

MODEL: LUCAS PCL - River2 (Sheet)
FILE NAME: p:\projects\transp\ppl\lucad\Documents\Projects_2018\CH401\401180022\03-MSV\CD\62R23-RB-1_Sheets\Civil\02R23-shed\mainprofile.dgn

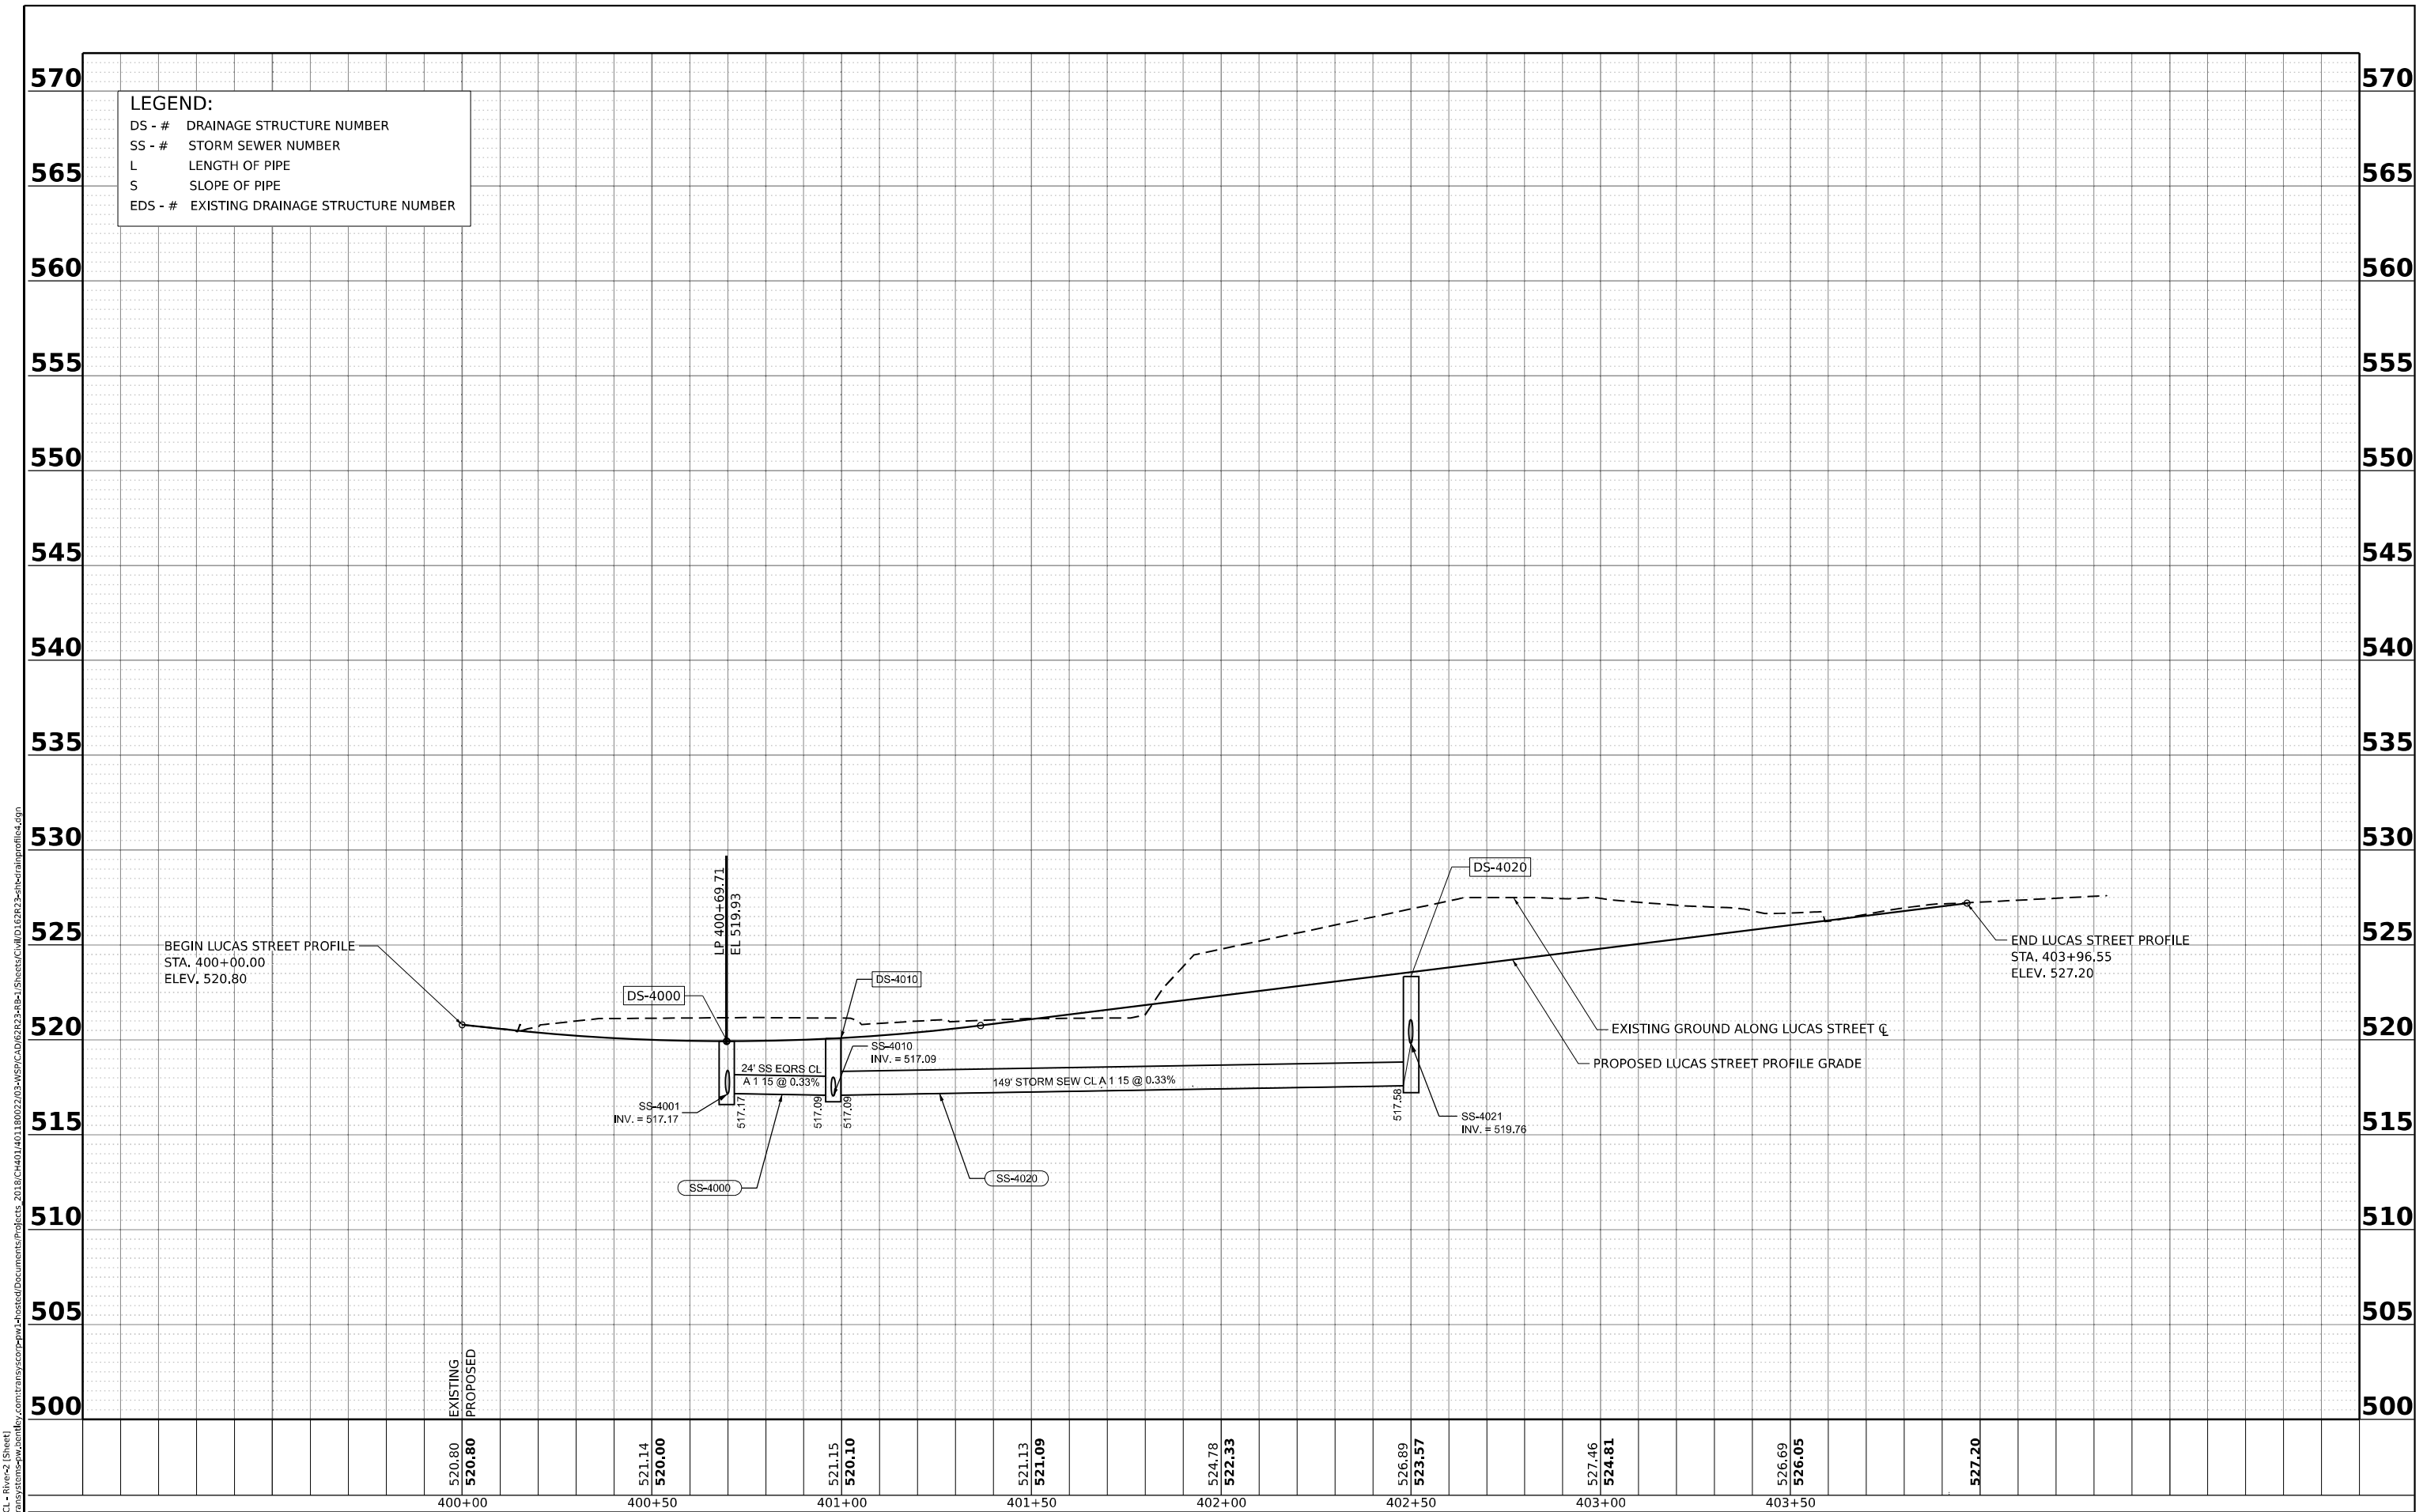

wsp WSP USA INC. 30 N. LASALLE STREET SUITE 4200 CHICAGO, IL 60602 TEL: (312) 782-8150 MODEL: LUCAS FILE NAME: DWG	USER NAME = USHC706648		DESIGNED - AKG	REVISED -	STATE OF ILLINOIS DEPARTMENT OF TRANSPORTATION	PROPOSED DRAINAGE AND UTILITY PROFILE LUCAS STREET					F.A.I. RTE.	SECTION		COUNTY	TOTAL SHEETS	SHEET NO.
	DRAWN - SSM		REVIS	ED							80	FAI 80 21 STRUCTURE 2		WILL	1230	358
	PLOT SCALE = 0.16666667' / in.		CHECKED - KS	REVIS							CONTRACT NO. 62R23					
	PLOT DATE = 11/6/2025		DATE - 11/7/2025	REVISED -												
			SCALE: HORIZ: 1"=20' VERT: 1"=5'			SHEET 1 OF 1 SHEETS		STA. TO STA.		ILLINOIS FED. AID PROJECT						

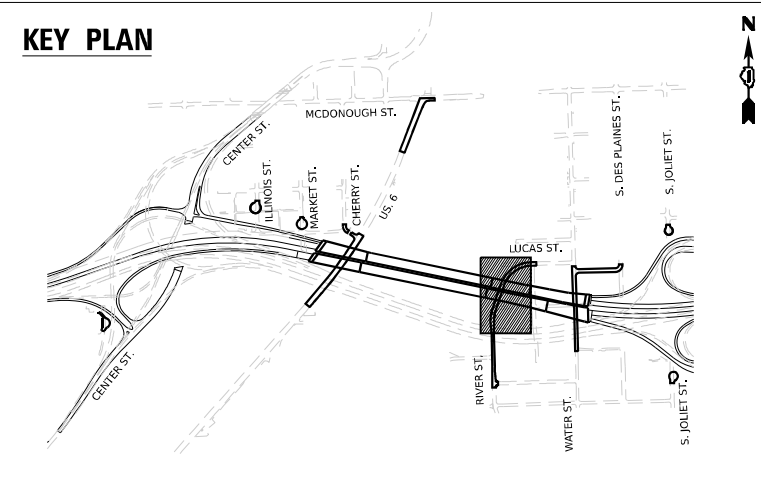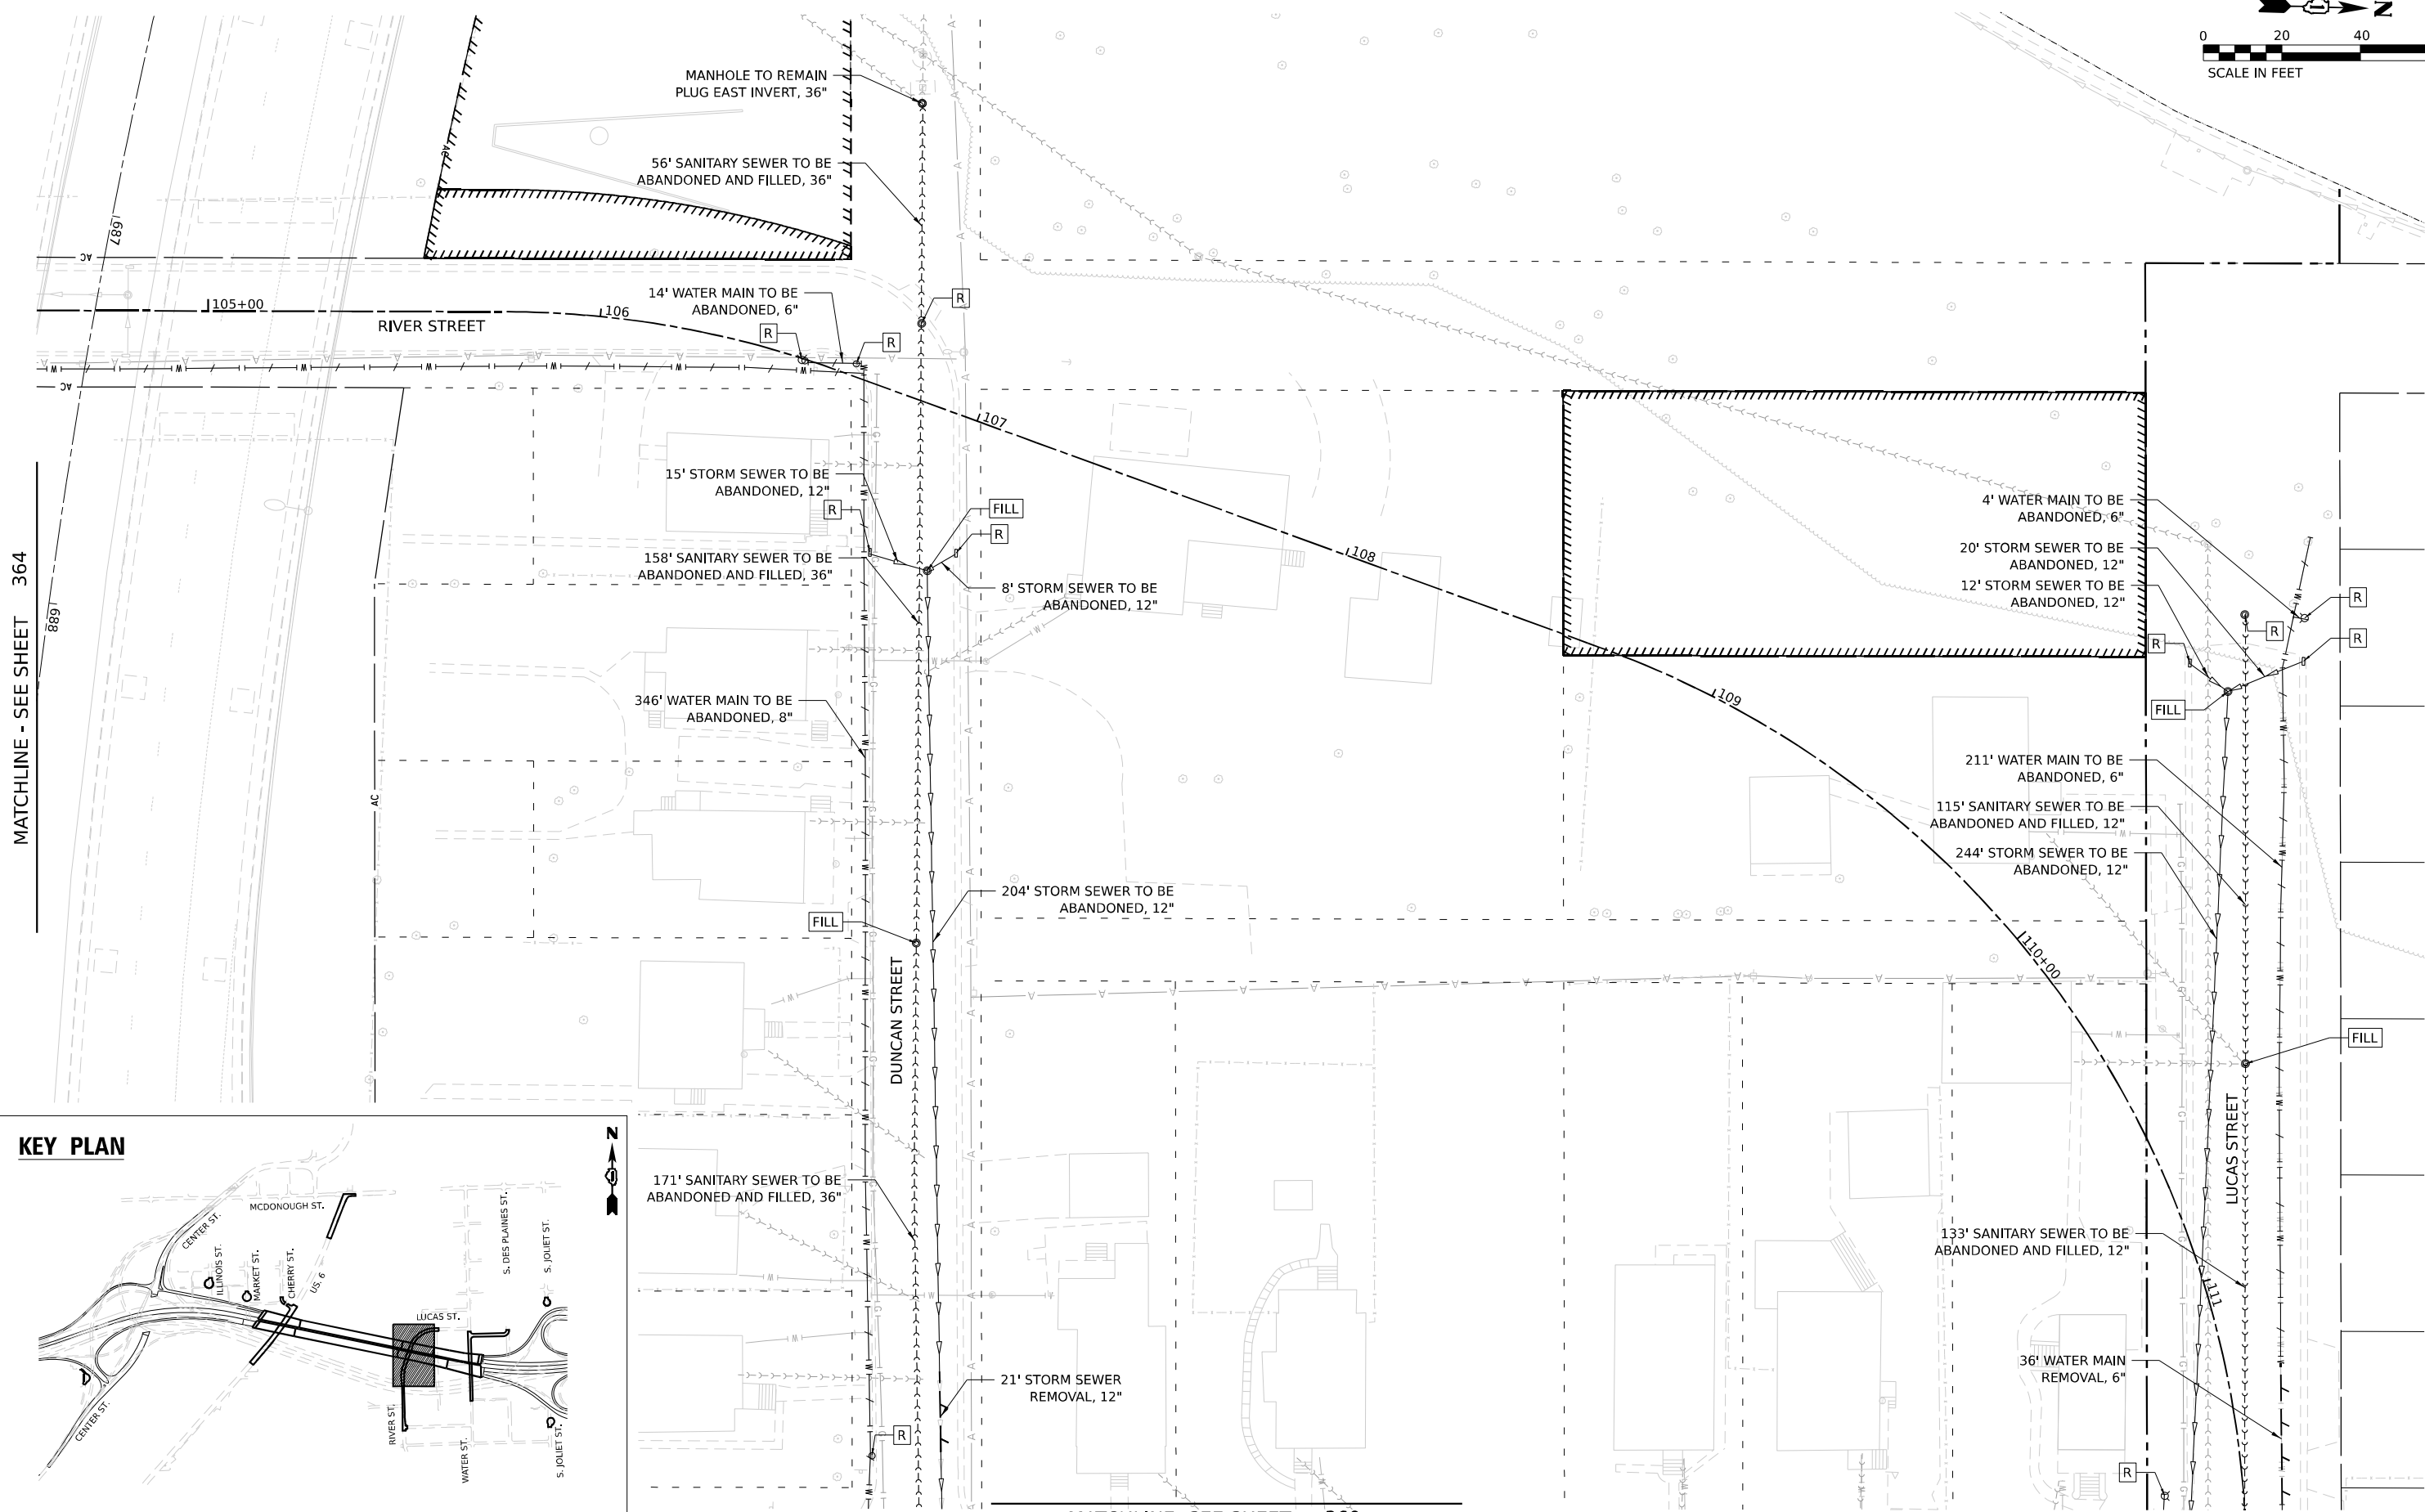 



 V3 Companies 7325 Janes Avenue Woodridge, IL 60517 630.724.9200 phone 630.724.9202 fax www.v3co.com	USER NAME = dpung	DESIGNED - CD	REVISED -	STATE OF ILLINOIS DEPARTMENT OF TRANSPORTATION	JOLIET UTILITY REMOVAL PLAN	F.A.I. RTE. 80	SECTION FAI 80 21 STRUCTURE 2	COUNTY WILL	TOTAL SHEETS 1230	SHEET NO. 359
		DRAWN - DP	REVISED -							
	PLOT SCALE =	CHECKED - JH	REVISED -							
	PLOT DATE = 11/6/2025	DATE - 11/7/2025	REVISED -							
SCALE: 1"=20'		SHEET 1 OF 9 SHEETS			STA. TO STA.		ILLINOIS FED. AID PROJECT			
CONTRACT NO. 62R23										

MODEL: Default: p:\trans\stones-pw-bentley.com\trans\stones-pw\labeled\Documents\Projects_2018\C4001401180022\03-WSP\project_info\Utilities\CO\12-Utilities\62R23-4B-1\Sheets\62R23-sh-removal2.dgn
FILE NAME: p:\trans\stones-pw-bentley.com\trans\stones-pw\labeled\Documents\Projects_2018\C4001401180022\03-WSP\project_info\Utilities\CO\12-Utilities\62R23-4B-1\Sheets\62R23-sh-removal2.dgn

MATCHLINE - SEE SHEET 364

MATCHLINE - SEE SHEET 359

MATCHLINE SEE SHEET 3 OF 11

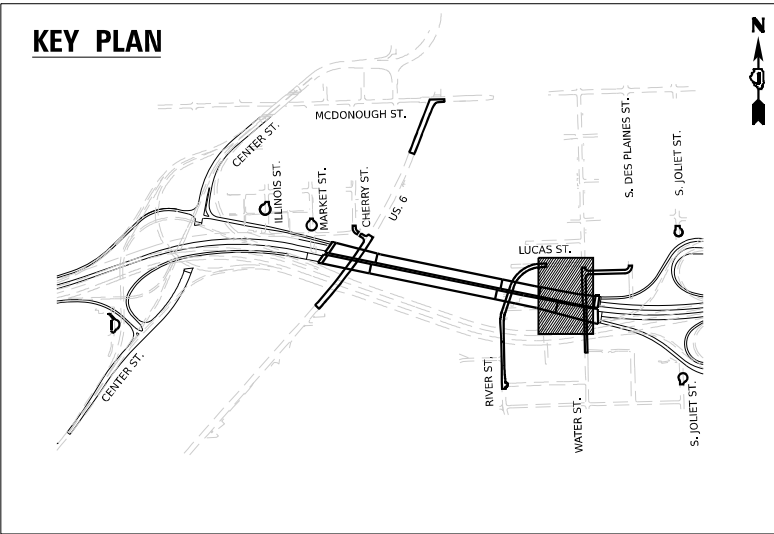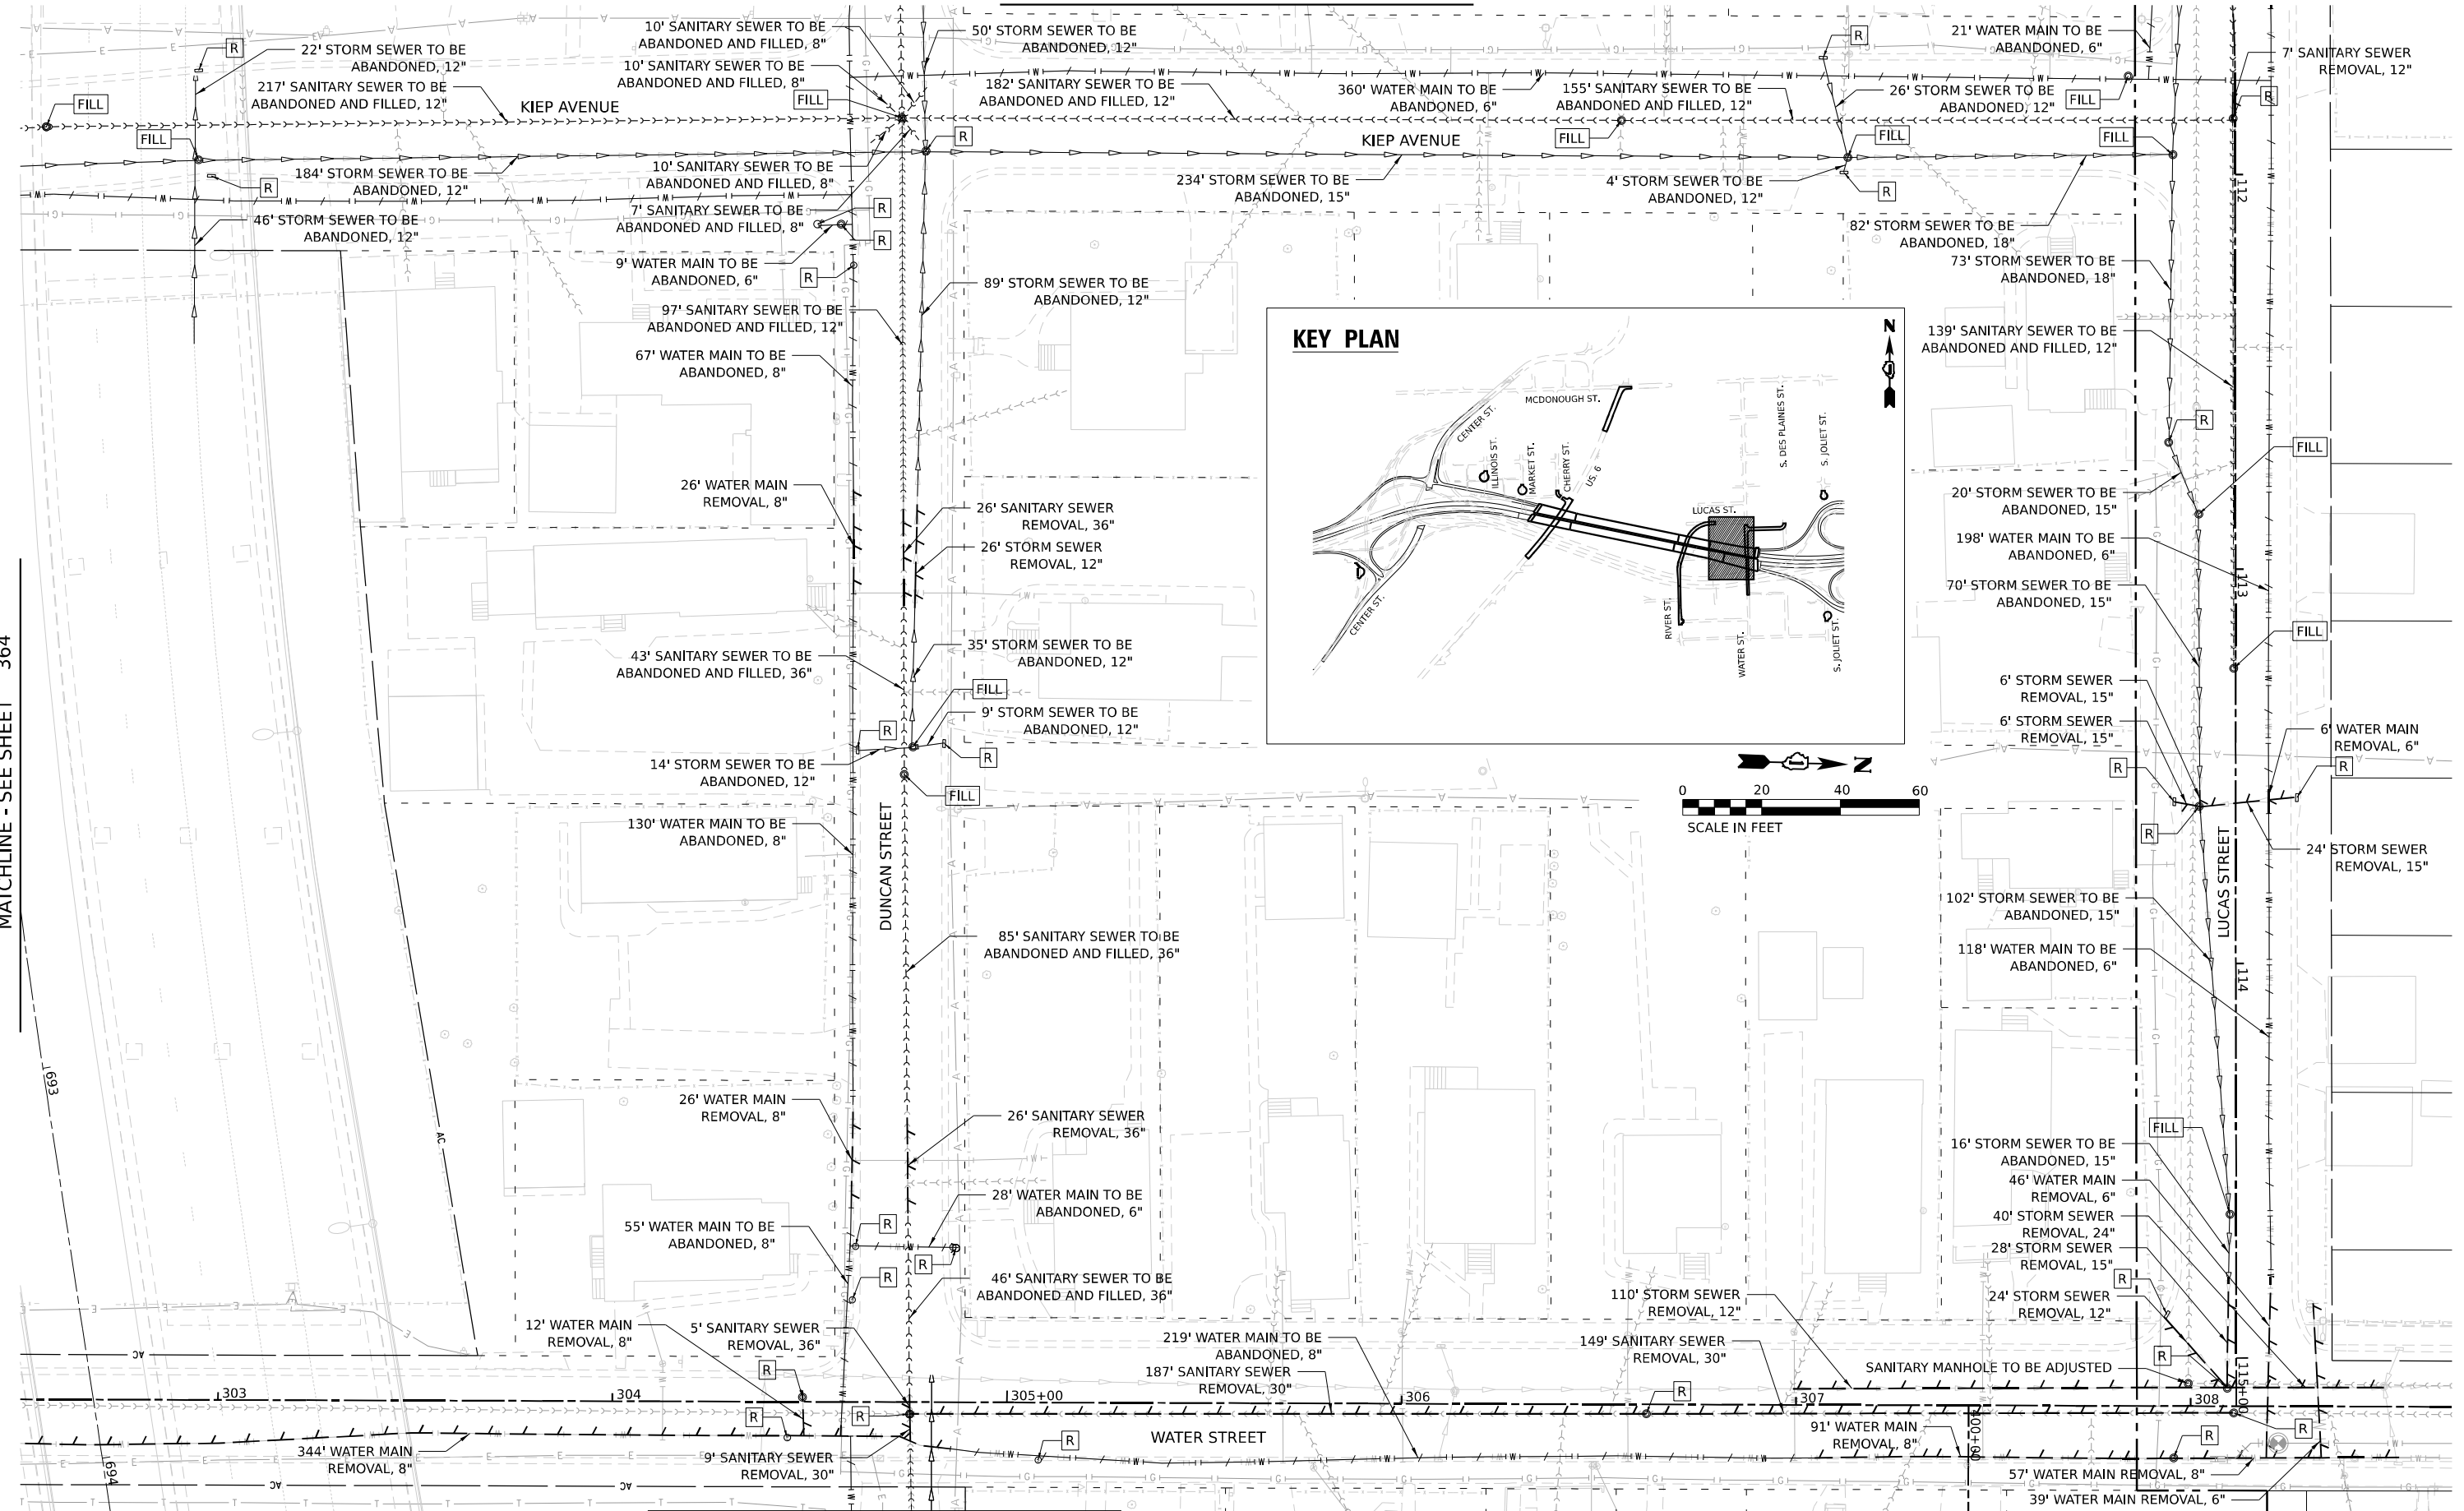

V3 Companies
7325 Jones Avenue
Woodridge, IL 60517
630.724.9200 phone
630.724.9202 fax
www.v3co.com

USER NAME = dpung
DESIGNED - CD
DRAWN - DP
CHECKED - JH
DATE - 11/7/2025
PLOT SCALE =
PLOT DATE = 11/6/2025

REVISD -
REVISED -
REVISED -
REVISED -

STATE OF ILLINOIS
DEPARTMENT OF TRANSPORTATION


JOLIET UTILITY REMOVAL PLAN

SCALE: 1"=20'
SHEET 2 OF 9 SHEETS
STA. TO STA.

F.A.I. RTE.	SECTION	COUNTY	TOTAL SHEETS	SHEET NO.
80	FAI 80 21 STRUCTURE 2	WILL	1230	360
CONTRACT NO. 62R23				
ILLINOIS FED. AID PROJECT				

MODEL: Default: p:\transystems-pw\bartley.com\transyscorp\pw1-hosted\Documents\Projects_2018\CH401\401180022\03-WSP\project_info\utilities\CO1\2-Utilities\62R23-sh-removal4.dgn

 MATCHLINE - SEE SHEET 361



V3 Companies
7325 Janes Avenue
Woodridge, IL 60517
630.724.9200 phone
630.724.9202 fax
www.v3co.com

USER NAME = dpung
PLOT SCALE =
PLOT DATE = 11/6/2025

DESIGNED - CD
DRAWN - DP
CHECKED - JH
DATE - 11/7/2025

REVISED -
REVISED -
REVISED -
REVISED -


STATE OF ILLINOIS
DEPARTMENT OF TRANSPORTATION

JOLIET UTILITY REMOVAL PLAN

SCALE: 1"=20' SHEET 4 OF 9 SHEETS STA. TO STA.

F.A.I. RTE.	SECTION	COUNTY	TOTAL SHEETS	SHEET NO.
80	FAI 80 21 STRUCTURE 2	WILL	1230	362
CONTRACT NO. 62R23				
ILLINOIS		FED. AID PROJECT		

KEY PLAN

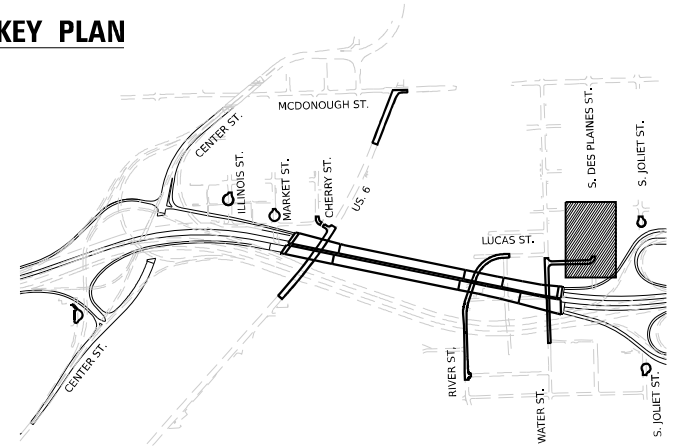

142' SANITARY SEWER TO BE
ABANDONED AND FILLED, 12"

43' WATER MAIN
REMOVAL, 12"

FILL

115' SANITARY SEWER TO BE
ABANDONED AND FILLED, 12"

10' SANITARY SEWER TO BE
ABANDONED AND FILLED, 12"

10' SANITARY SEWER
REMOVAL, 12"

58' SANITARY SEWER TO BE
ABANDONED AND FILLED, 10"

10' SANITARY SEWER
REMOVAL, 10"

5' SANITARY SEWER
REMOVAL, 10"

5' SANITARY SEWER
REMOVAL, 12"

76' SANITARY SEWER TO BE
ABANDONED AND FILLED, 10"

27' SANITARY SEWER TO BE
ABANDONED AND FILLED, 10"

31' SANITARY SEWER TO BE
ABANDONED AND FILLED, 10"

17' SANITARY SEWER TO BE
ABANDONED AND FILLED, 10"

10' SANITARY SEWER
REMOVAL, 10"

25' SANITARY SEWER
REMOVAL, 18"

25' SANITARY SEWER TO BE
ABANDONED AND FILLED, 10"

10' SANITARY SEWER
REMOVAL, 10"


 

10' SANITARY SEWER
REMOVAL, 10"

3' SANITARY SEWER
REMOVAL, 10"

21' SANITARY
SEWER
REMOVAL, 18"



MATCHLINE SEE SHEET 5 OF 9

MODEL: Default
FILE NAME: p:\projtrans\stone-pw\bartley.com\trans\corp-pw\hosted\Documents\Projects_2018\C4001401180022\03-W59\project_info\utilities\COU-V3-Utilities\62R23-4B-1\Sheets\DJ62R23-sh-removal6.dgn

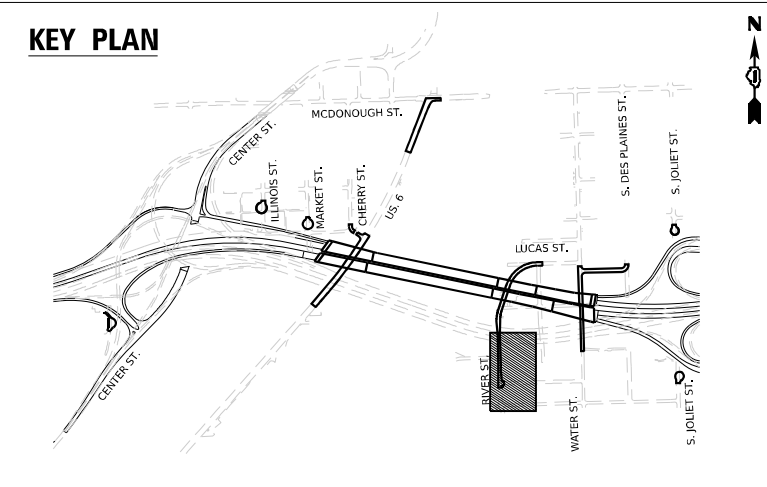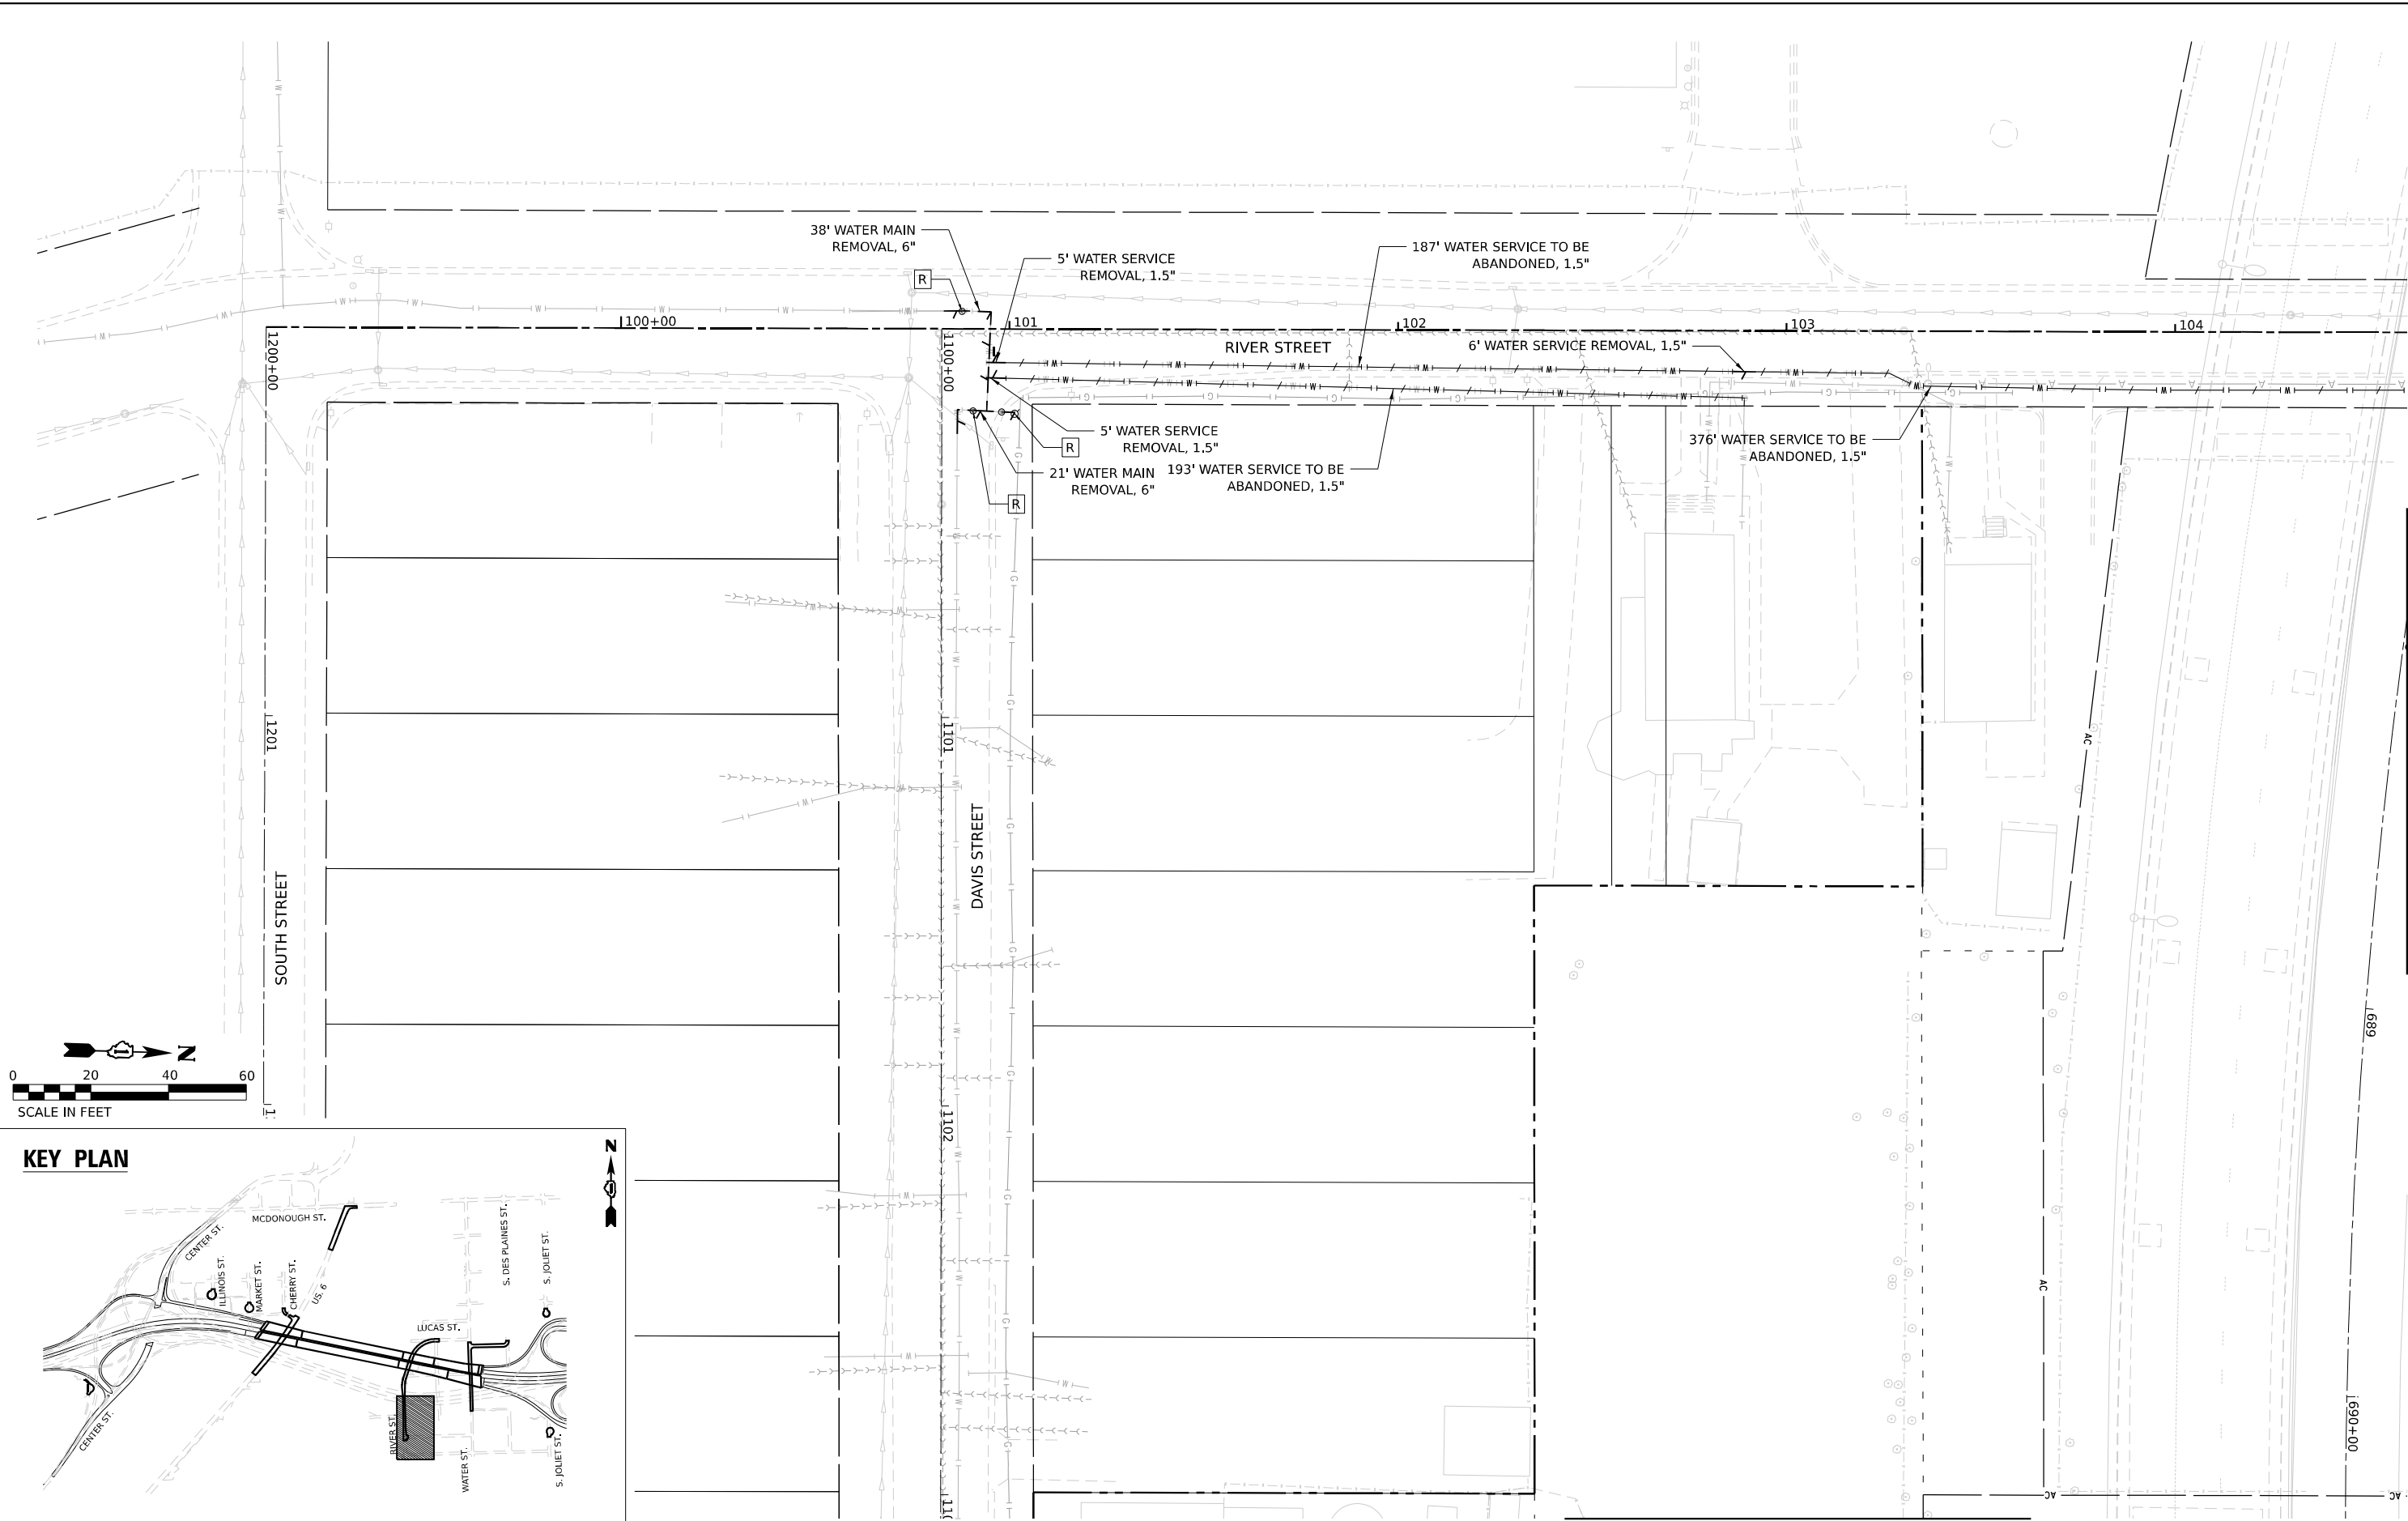


 V3 Companies 7325 Janes Avenue Woodridge, IL 60517 630.724.9200 phone 630.724.9202 fax www.v3co.com	USER NAME = dpung		DESIGNED - CD	REVISED -	STATE OF ILLINOIS DEPARTMENT OF TRANSPORTATION	JOLIET UTILITY REMOVAL PLAN				F.A.I. RTE.	SECTION	COUNTY	TOTAL SHEETS	SHEET NO.
	DRAWN - DP		CHECKED - JH	REVISED -		SCALE: 1"=20'				80	FAI 80 21 STRUCTURE 2	WILL	1230	364
	PLOT SCALE =		DATE - 11/7/2025	REVISED -		SHEET 6 OF 9 SHEETS STA. TO STA.				CONTRACT NO. 62R23				
	PLOT DATE = 11/6/2025									ILLINOIS FED. AID PROJECT				

MODEL: Default
FILE NAME: p:\projects\trans\stone-pw-bentley.com\trans\corp-pw1-hosted\Documents\Projects_2018\CH401\401180022\03-WSP77\project_info\utilities\CO1-V3-Utilities\62R23-4B-1\Sheets\62R23-sh-removal17.dgn

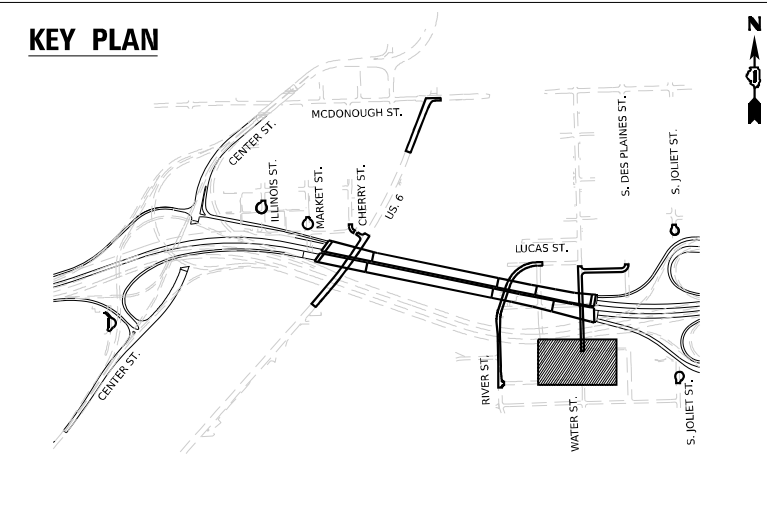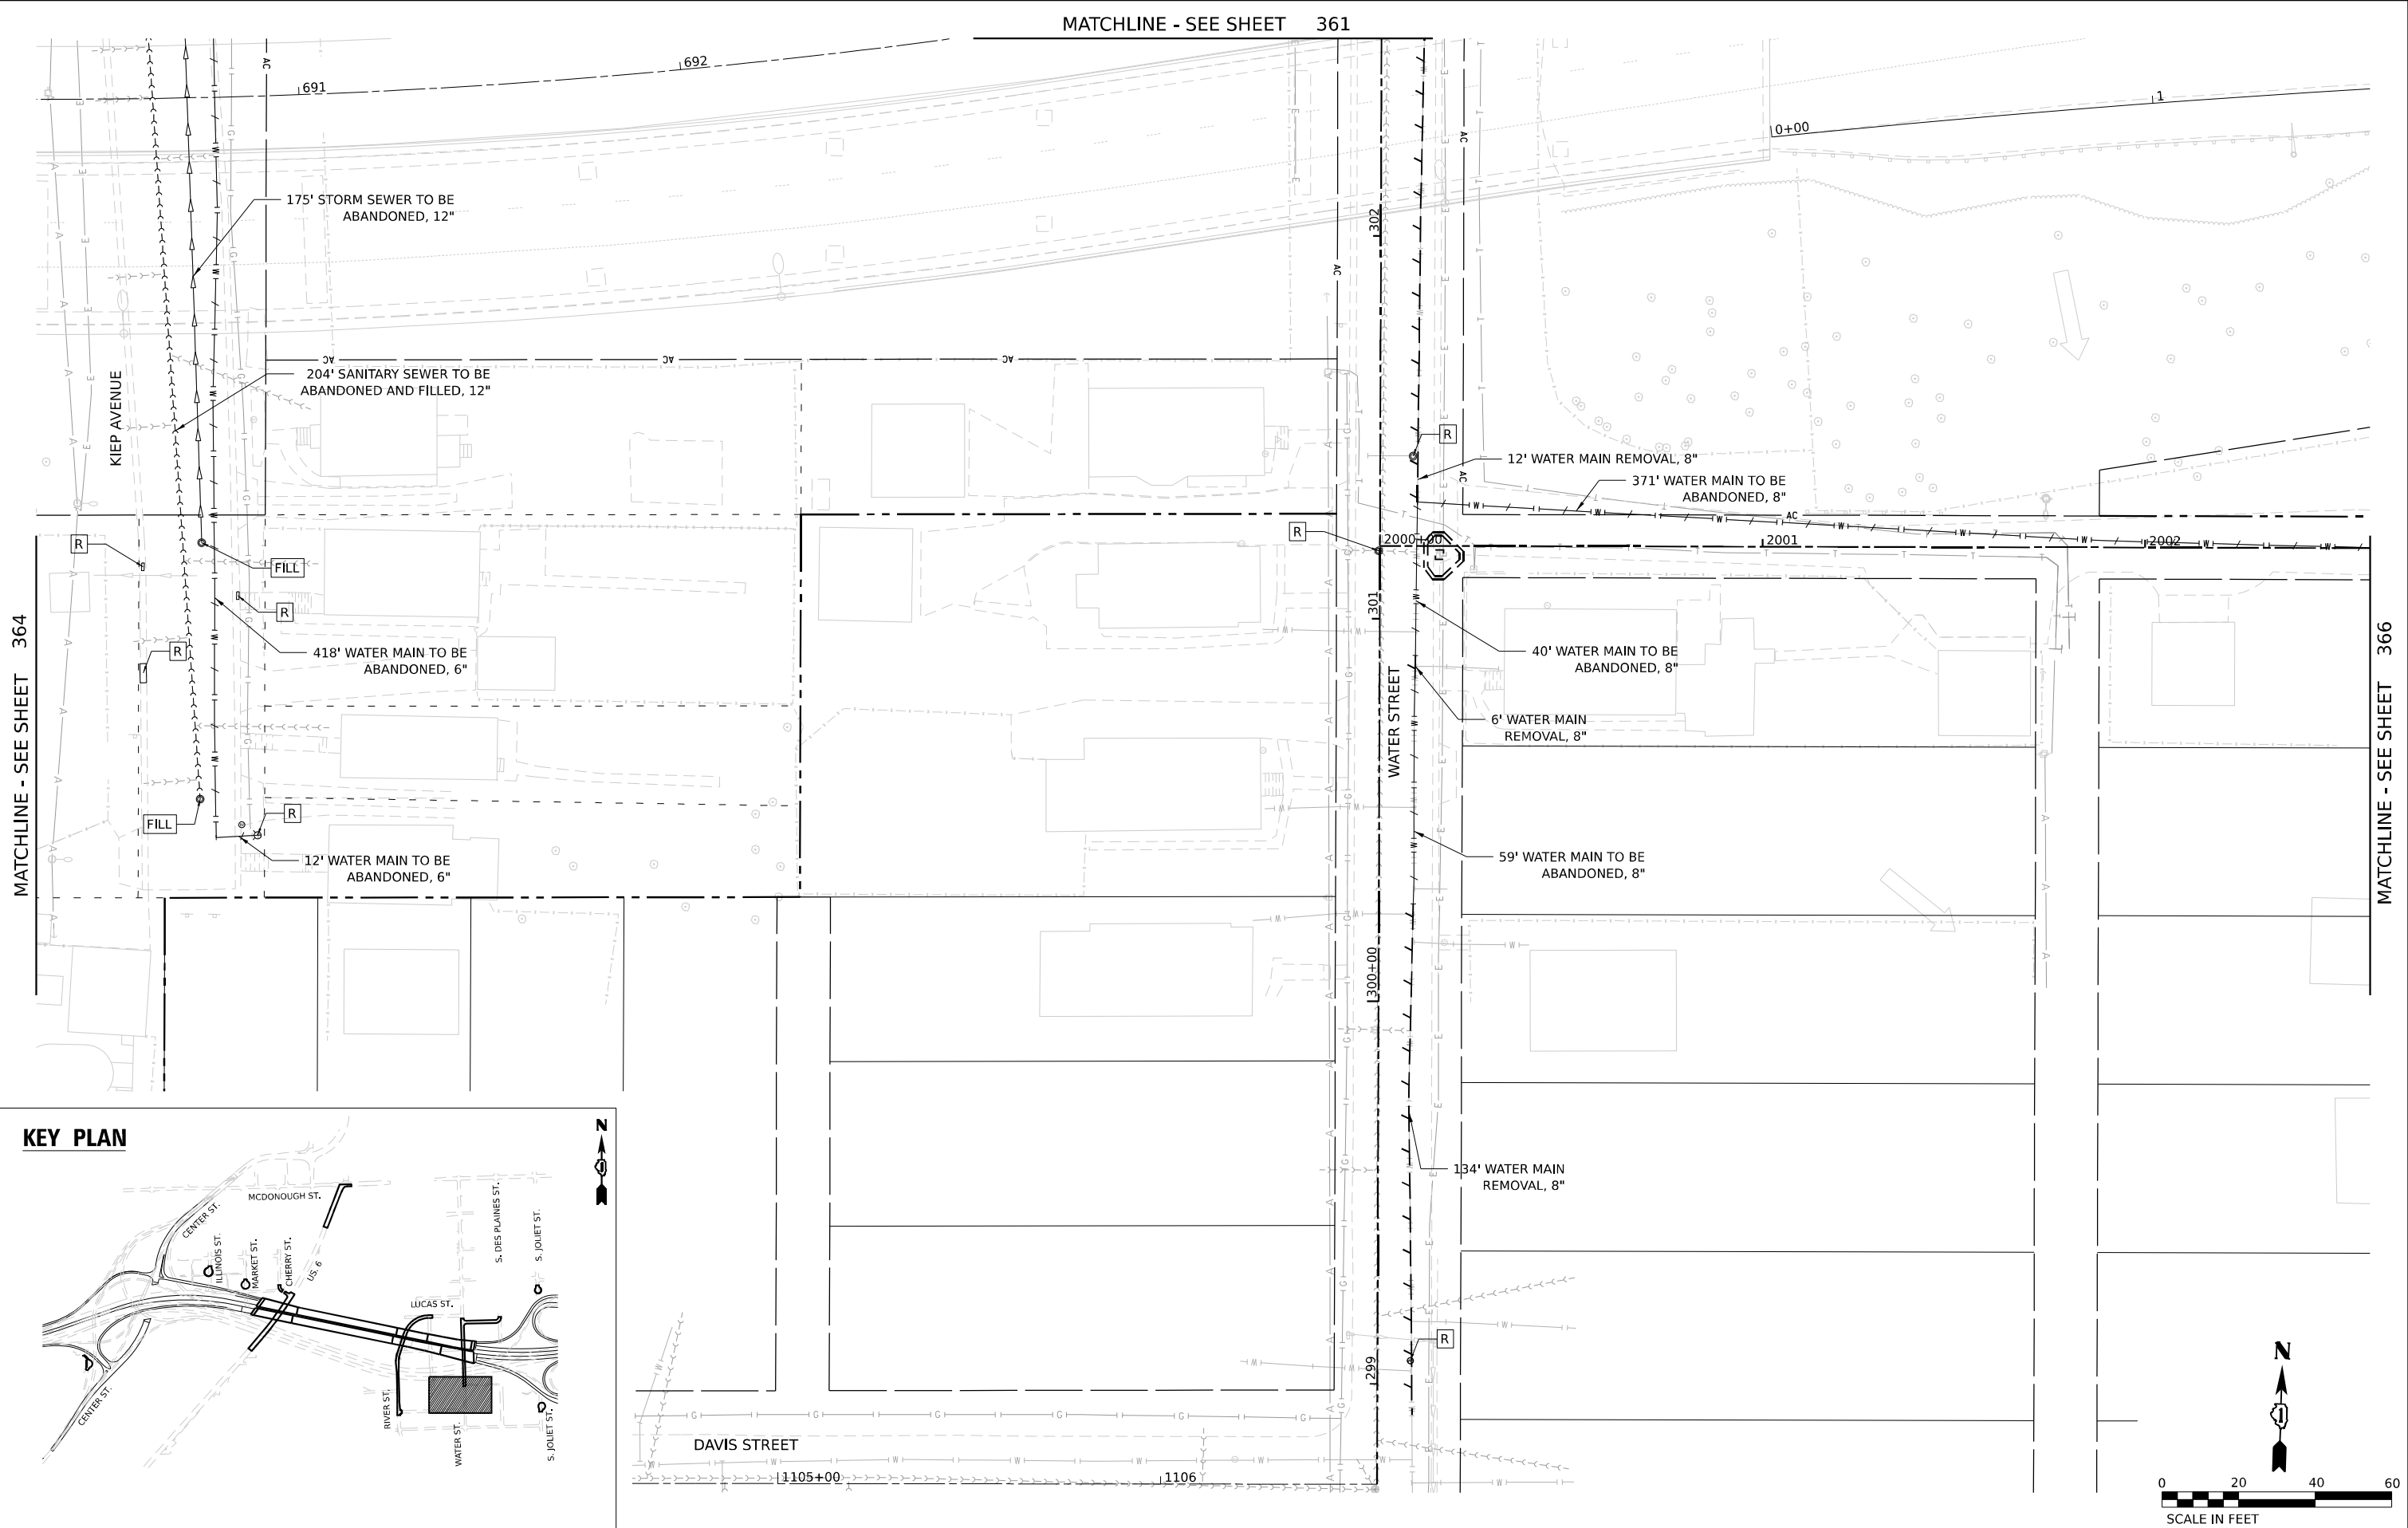



	V3 Companies 7325 Janes Avenue Woodridge, IL 60517 630.724.9200 phone 630.724.9202 fax www.v3co.com	USER NAME = dpung	DESIGNED - CD	REVISED -	STATE OF ILLINOIS DEPARTMENT OF TRANSPORTATION	JOLIET UTILITY REMOVAL PLAN				F.A.I. RTE.	SECTION	COUNTY	TOTAL SHEETS	SHEET NO.															
		DRAWN - DP	REVISED -	80		FAI 80 21 STRUCTURE 2	WILL	1230	365																				
	PLOT SCALE =	CHECKED - JH	REVISED -	CONTRACT NO. 62R23																									
	PLOT DATE = 11/6/2025	DATE - 11/7/2025	REVISED -	SCALE: 1"=20'		SHEET 7	OF 9	SHEETS	STA.	TO STA.																			
ILLINOIS															FED. AID PROJECT														

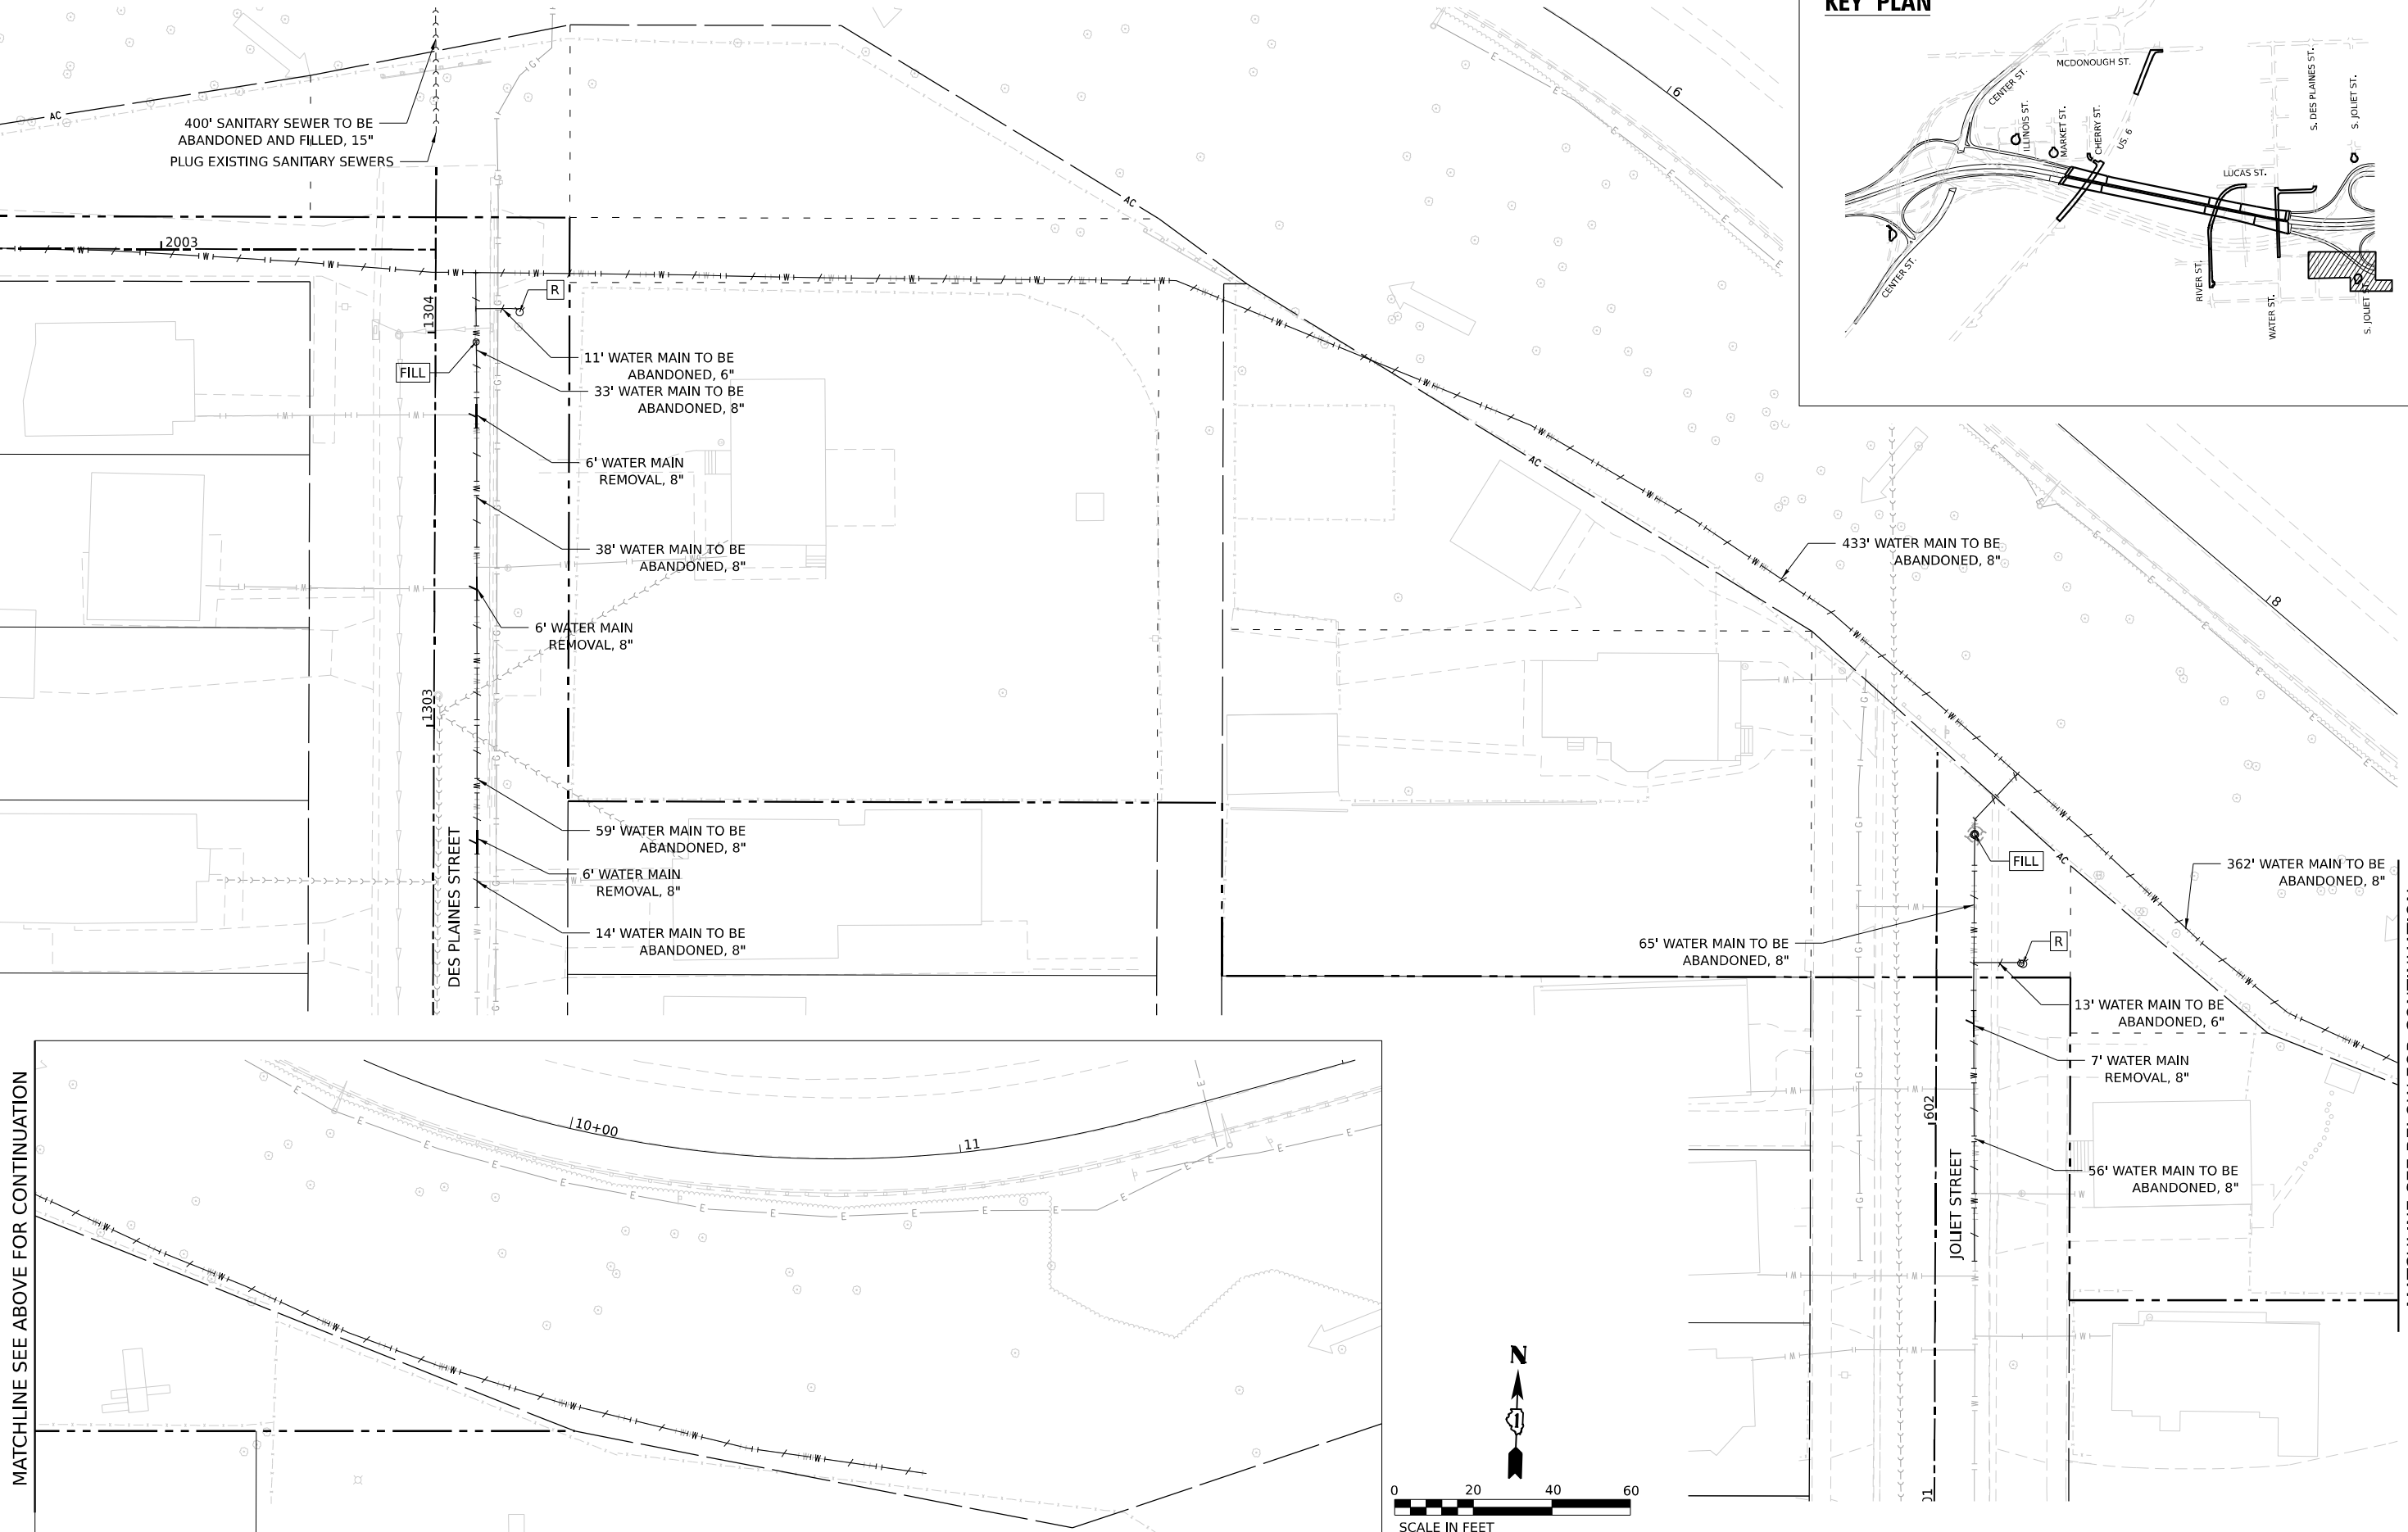

MATCHLINE SEE ABOVE FOR CONTINUATION

MATCHLINE SEE BELOW FOR CONTINUATION

KEY PLAN

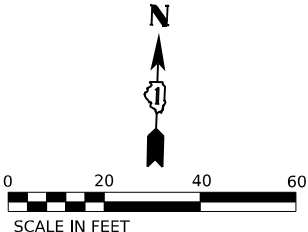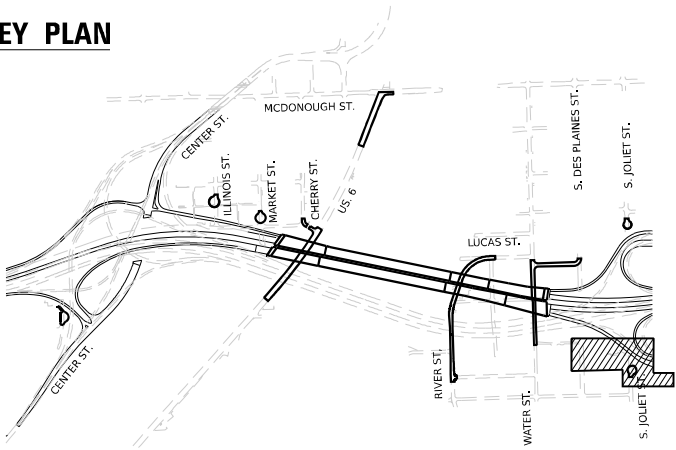

MODEL: Default
FILE NAME: p:\projects\trans\scorp\ppl\hosted\Documents\projects_2018\CH401\401180022\03-WSP\project_info\utilities\CO\12-Utilities\62R23-4B-1\Sheets\62R23-sh-removalB.dgn



V3 Companies
7325 Janes Avenue
Woodridge, IL 60517
630.724.9200 phone
630.724.9202 fax
www.v3co.com

USER NAME = dpung
PLOT SCALE =
PLOT DATE = 11/6/2025

DESIGNED - CD
DRAWN - DP
CHECKED - JH
DATE - 11/7/2025


REVISED -
REVISED -
REVISED -
REVISED -

STATE OF ILLINOIS
DEPARTMENT OF TRANSPORTATION


JOLIET UTILITY REMOVAL PLAN

SCALE: 1"=20' SHEET 8 OF 9 SHEETS STA. TO STA.

F.A.I. RTE.	SECTION	COUNTY	TOTAL SHEETS	SHEET NO.
80	FAI 80 21 STRUCTURE 2	WILL	1230	366
CONTRACT NO. 62R23				
ILLINOIS FED. AID PROJECT				

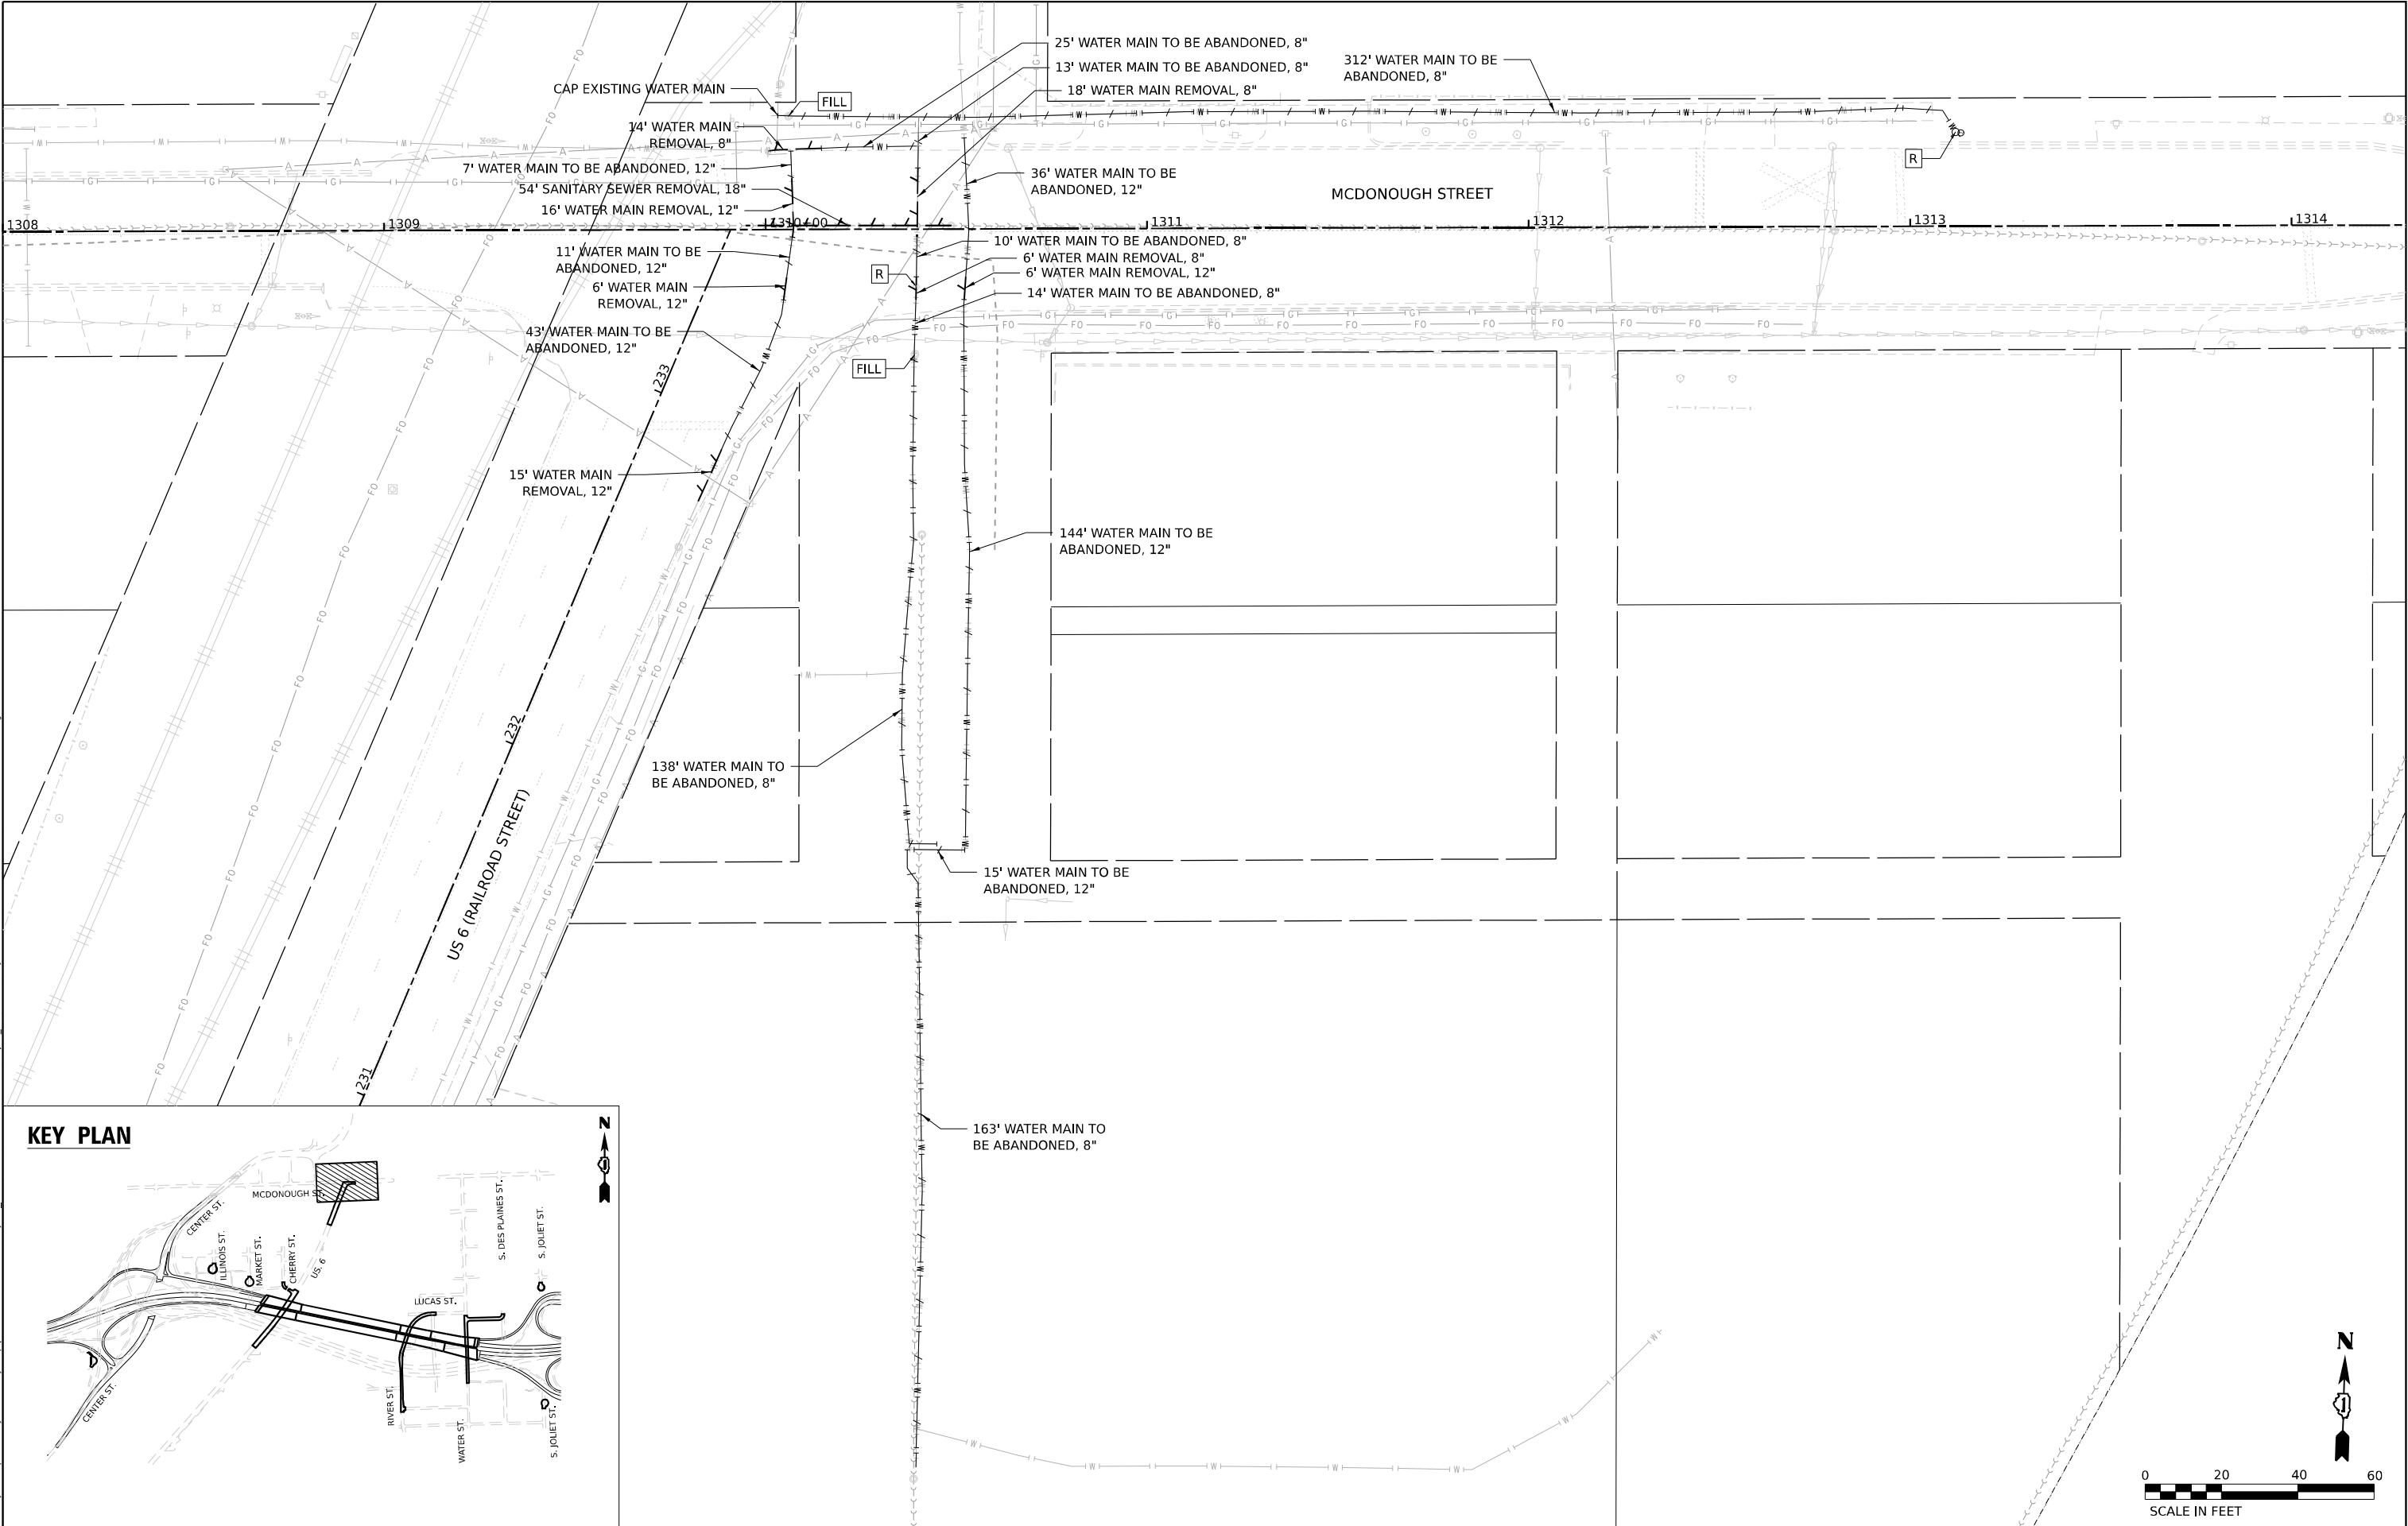

KEY PLAN

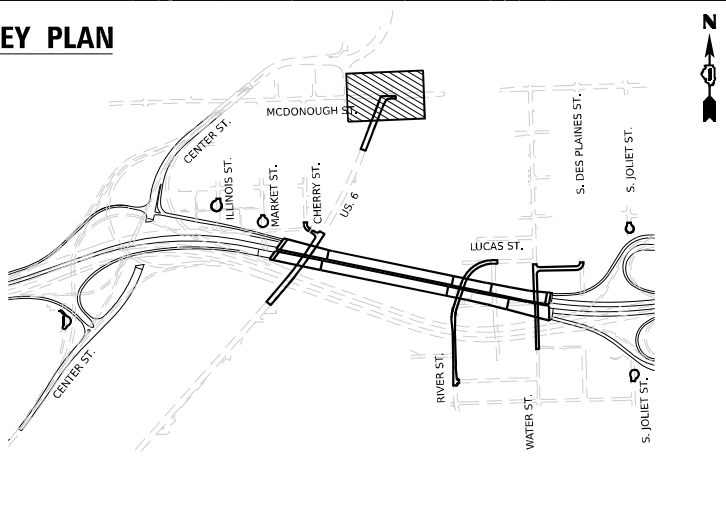

V3 Companies
7325 Janes Avenue
Woodridge, IL 60517
630.724.9200 phone
630.724.9202 fax
www.v3co.com

USER NAME	= dpung
PLOT SCALE	=
PLOT DATE	= 11/6/2025

DESIGNED -	CD
DRAWN -	DP
CHECKED -	JH
DATE -	11/7/2025

REVISED -	
REVISED -	
REVISED -	
REVISED -	

STATE OF ILLINOIS
DEPARTMENT OF TRANSPORTATION

JOLIET UTILITY REMOVAL PLAN

SCALE: 1"=20' SHEET 9 OF 9 SHEETS STA. TO STA.


F.A.I. RTE.	SECTION	COUNTY	TOTAL SHEETS	SHEET NO.
80	FAI 80 21 STRUCTURE 2	WILL	1230	367
CONTRACT NO. 62R23				
ILLINOIS FED. AID PROJECT				

PLAN	SURVEYED PLOTTED ALIGNMENT CHECKED AS SHOWN CADD FILE NAME	BY	DATE
NOTE BOOK NO.			


PROFILE	SURVEYED PLOTTED GRADES CHECKED STRUCTURE NOTATIONS CHKD	BY	DATE
NOTE BOOK NO.			

MODEL Default
FILE NAME: p:\w\transystems\pub\ent\key.com\transys\corp\pw1\shaded\Documents\Projects\2018\CH401\401180022\03-VS7\project_Info\Utilities\CO-VS-Utilities\62R23-4B-1\Sheets\0162R23-sh-train01.dgn

VV-1 4' DIA. VALVE VAULT TYPE A, TYPE 1 FRAME, CLOSED LID STA 100+73.00, 24.19' LT RIM = 519.39 GATE VALVE, 8"	VV-2 4' DIA. VALVE VAULT TYPE A, TYPE 1 FRAME, CLOSED LID STA 100+93.08, 15.53' RT RIM = 518.80 GATE VALVE, 8"	VV-3 4' DIA. VALVE VAULT TYPE A, TYPE 1 FRAME, CLOSED LID STA 101+13.00, 24.19' LT RIM = 519.44 GATE VALVE, 8"
---	---	---

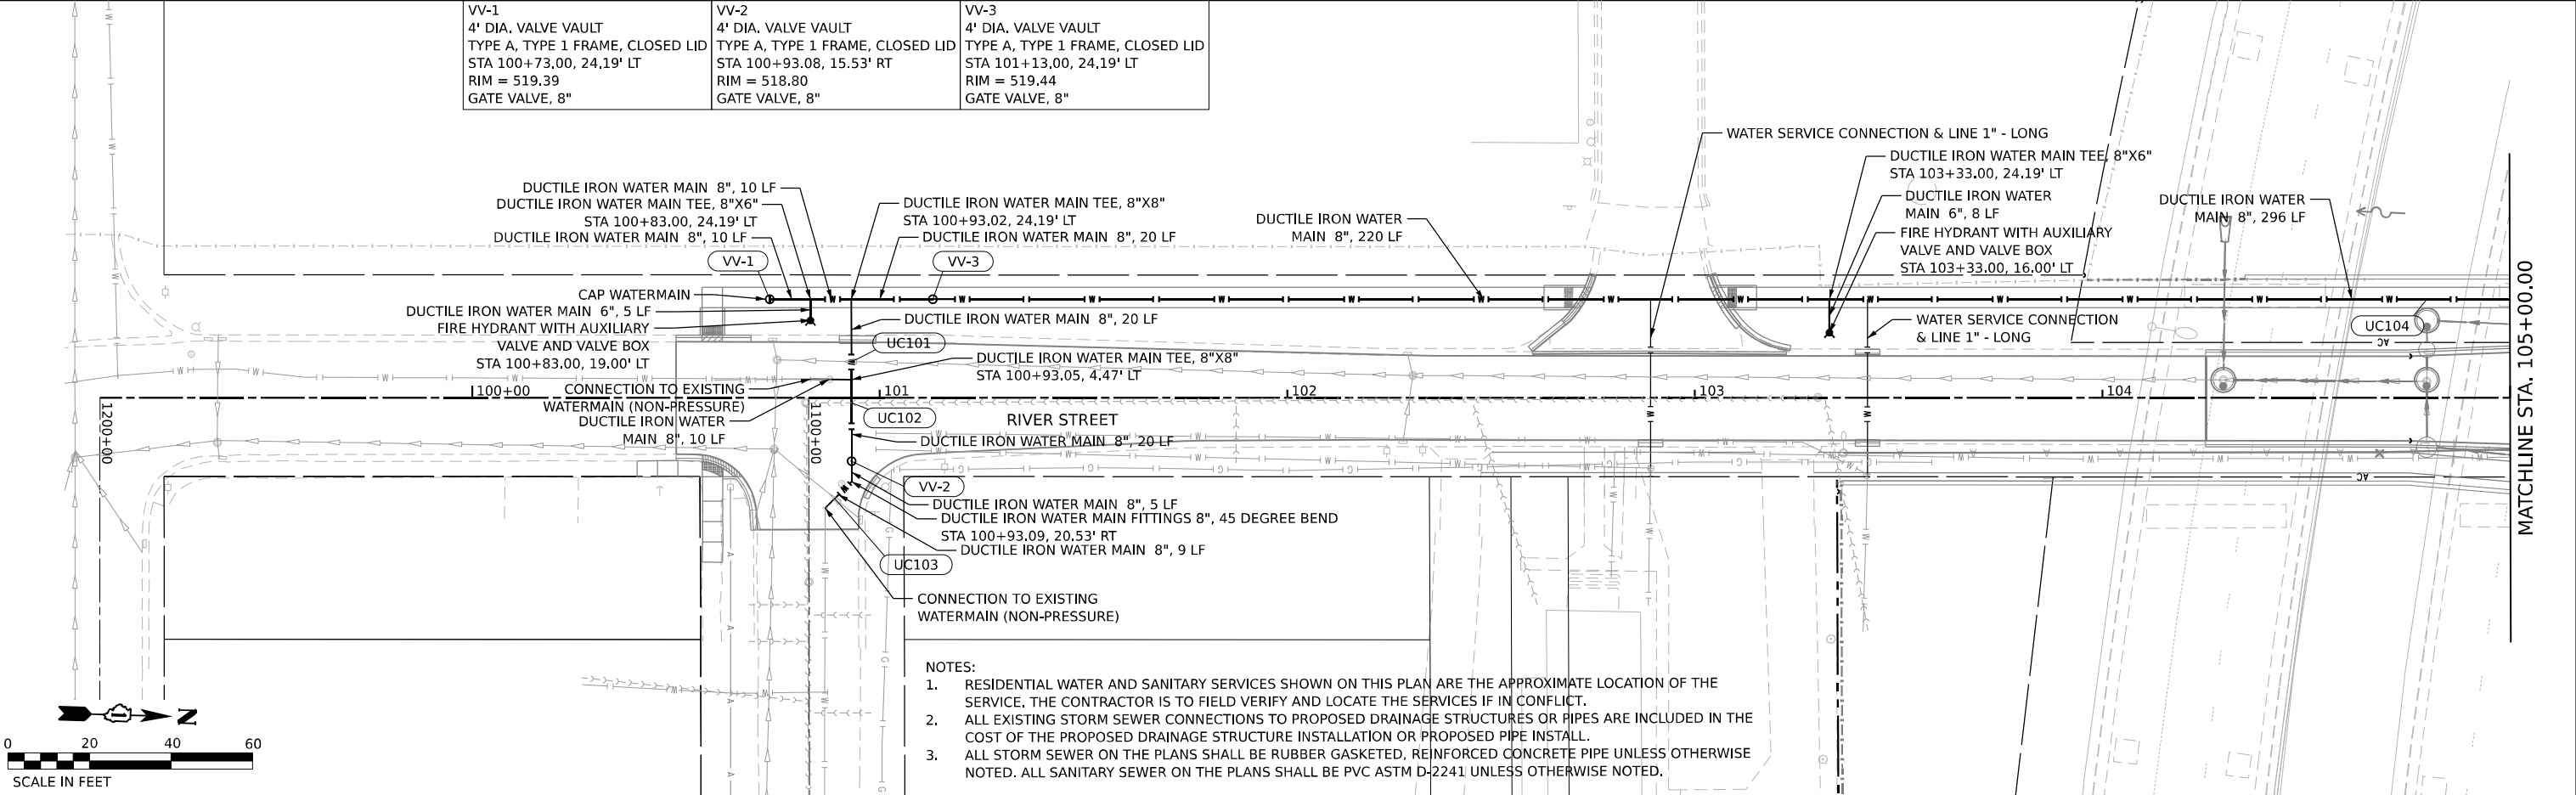

- NOTES:
1. RESIDENTIAL WATER AND SANITARY SERVICES SHOWN ON THIS PLAN ARE THE APPROXIMATE LOCATION OF THE SERVICE. THE CONTRACTOR IS TO FIELD VERIFY AND LOCATE THE SERVICES IF IN CONFLICT.
 2. ALL EXISTING STORM SEWER CONNECTIONS TO PROPOSED DRAINAGE STRUCTURES OR PIPES ARE INCLUDED IN THE COST OF THE PROPOSED DRAINAGE STRUCTURE INSTALLATION OR PROPOSED PIPE INSTALL.
 3. ALL STORM SEWER ON THE PLANS SHALL BE RUBBER GASKETED, REINFORCED CONCRETE PIPE UNLESS OTHERWISE NOTED. ALL SANITARY SEWER ON THE PLANS SHALL BE PVC ASTM D-2241 UNLESS OTHERWISE NOTED.

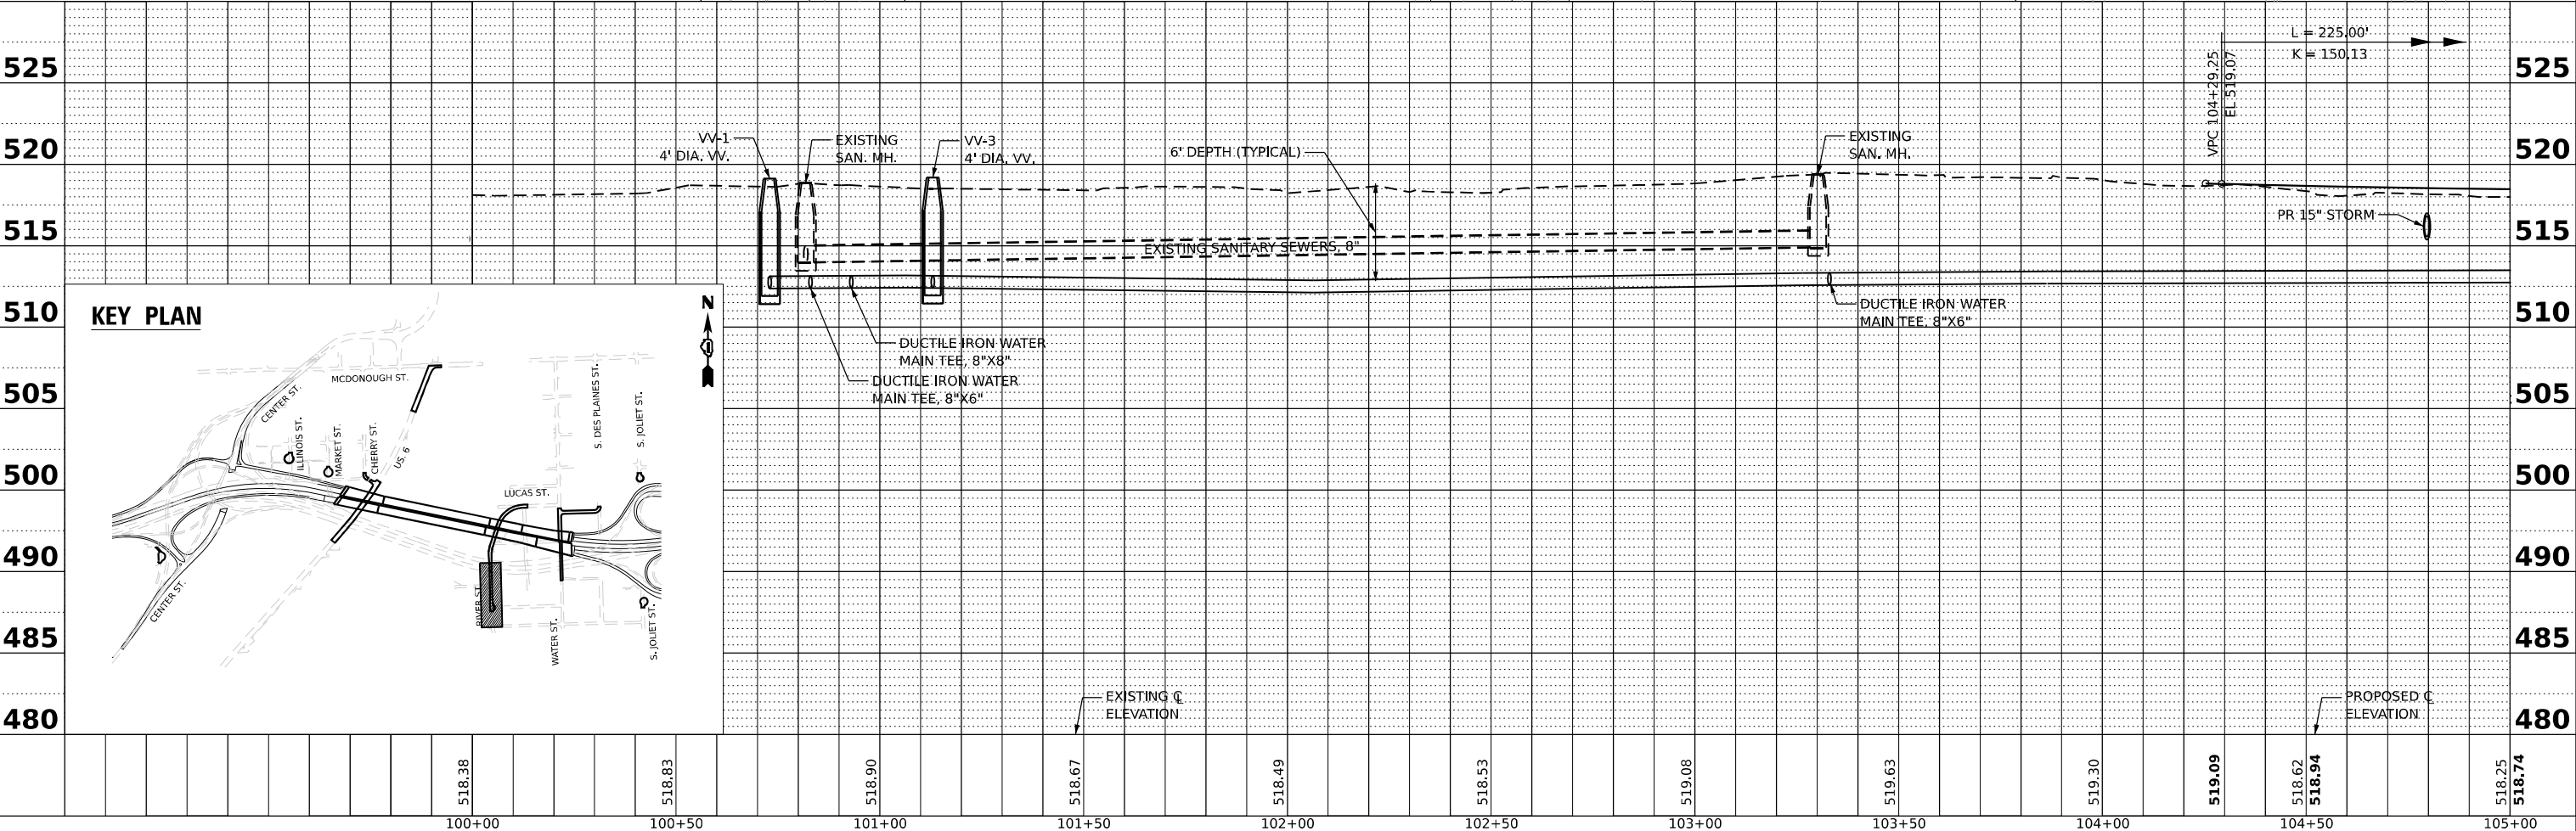

V3 Companies
7325 Janes Avenue
Woodridge, IL 60517
630.724.9200 phone
630.724.9202 fax
www.v3co.com

USER NAME	= dpung
PLOT SCALE	=
PLOT DATE	= 11/5/2025

DESIGNED	- CD
DRAWN	- DP
CHECKED	- JH
DATE	- 11/7/2025

REVISED	-
REVISED	-
REVISED	-
REVISED	-

STATE OF ILLINOIS
DEPARTMENT OF TRANSPORTATION

JOLIET DRAINAGE AND UTILITY PLAN & PROFILE


SCALE: 1"=20' SHEET 1 OF 13 SHEETS STA. 100+00.00 TO STA. 105+00.00

F.A.I. RTE.	SECTION	COUNTY	TOTAL SHEETS	SHEET NO.
80	FAI 80 21 STRUCTURE 2	WILL	1230	368
CONTRACT NO. 62R23				
ILLINOIS FED. AID PROJECT				

PLAN	SURVEYED PLOTTED ALIGNMENT CHECKED BY NO.	DATE

PROFILE	SURVEYED PLOTTED GRADES CHECKED BY NO.	DATE

MODEL: Default
FILE NAME: p:\v3\transystems\pub\blentley.com\transys\corp\pw\1\shaded\Documents\Projects\2018\CH401\401180022\03-V597\project_Info\Utilities\CO\V3-V5-Utilities\62R23-4B-1\Sheets\01 62R23-sh-train2.dgn

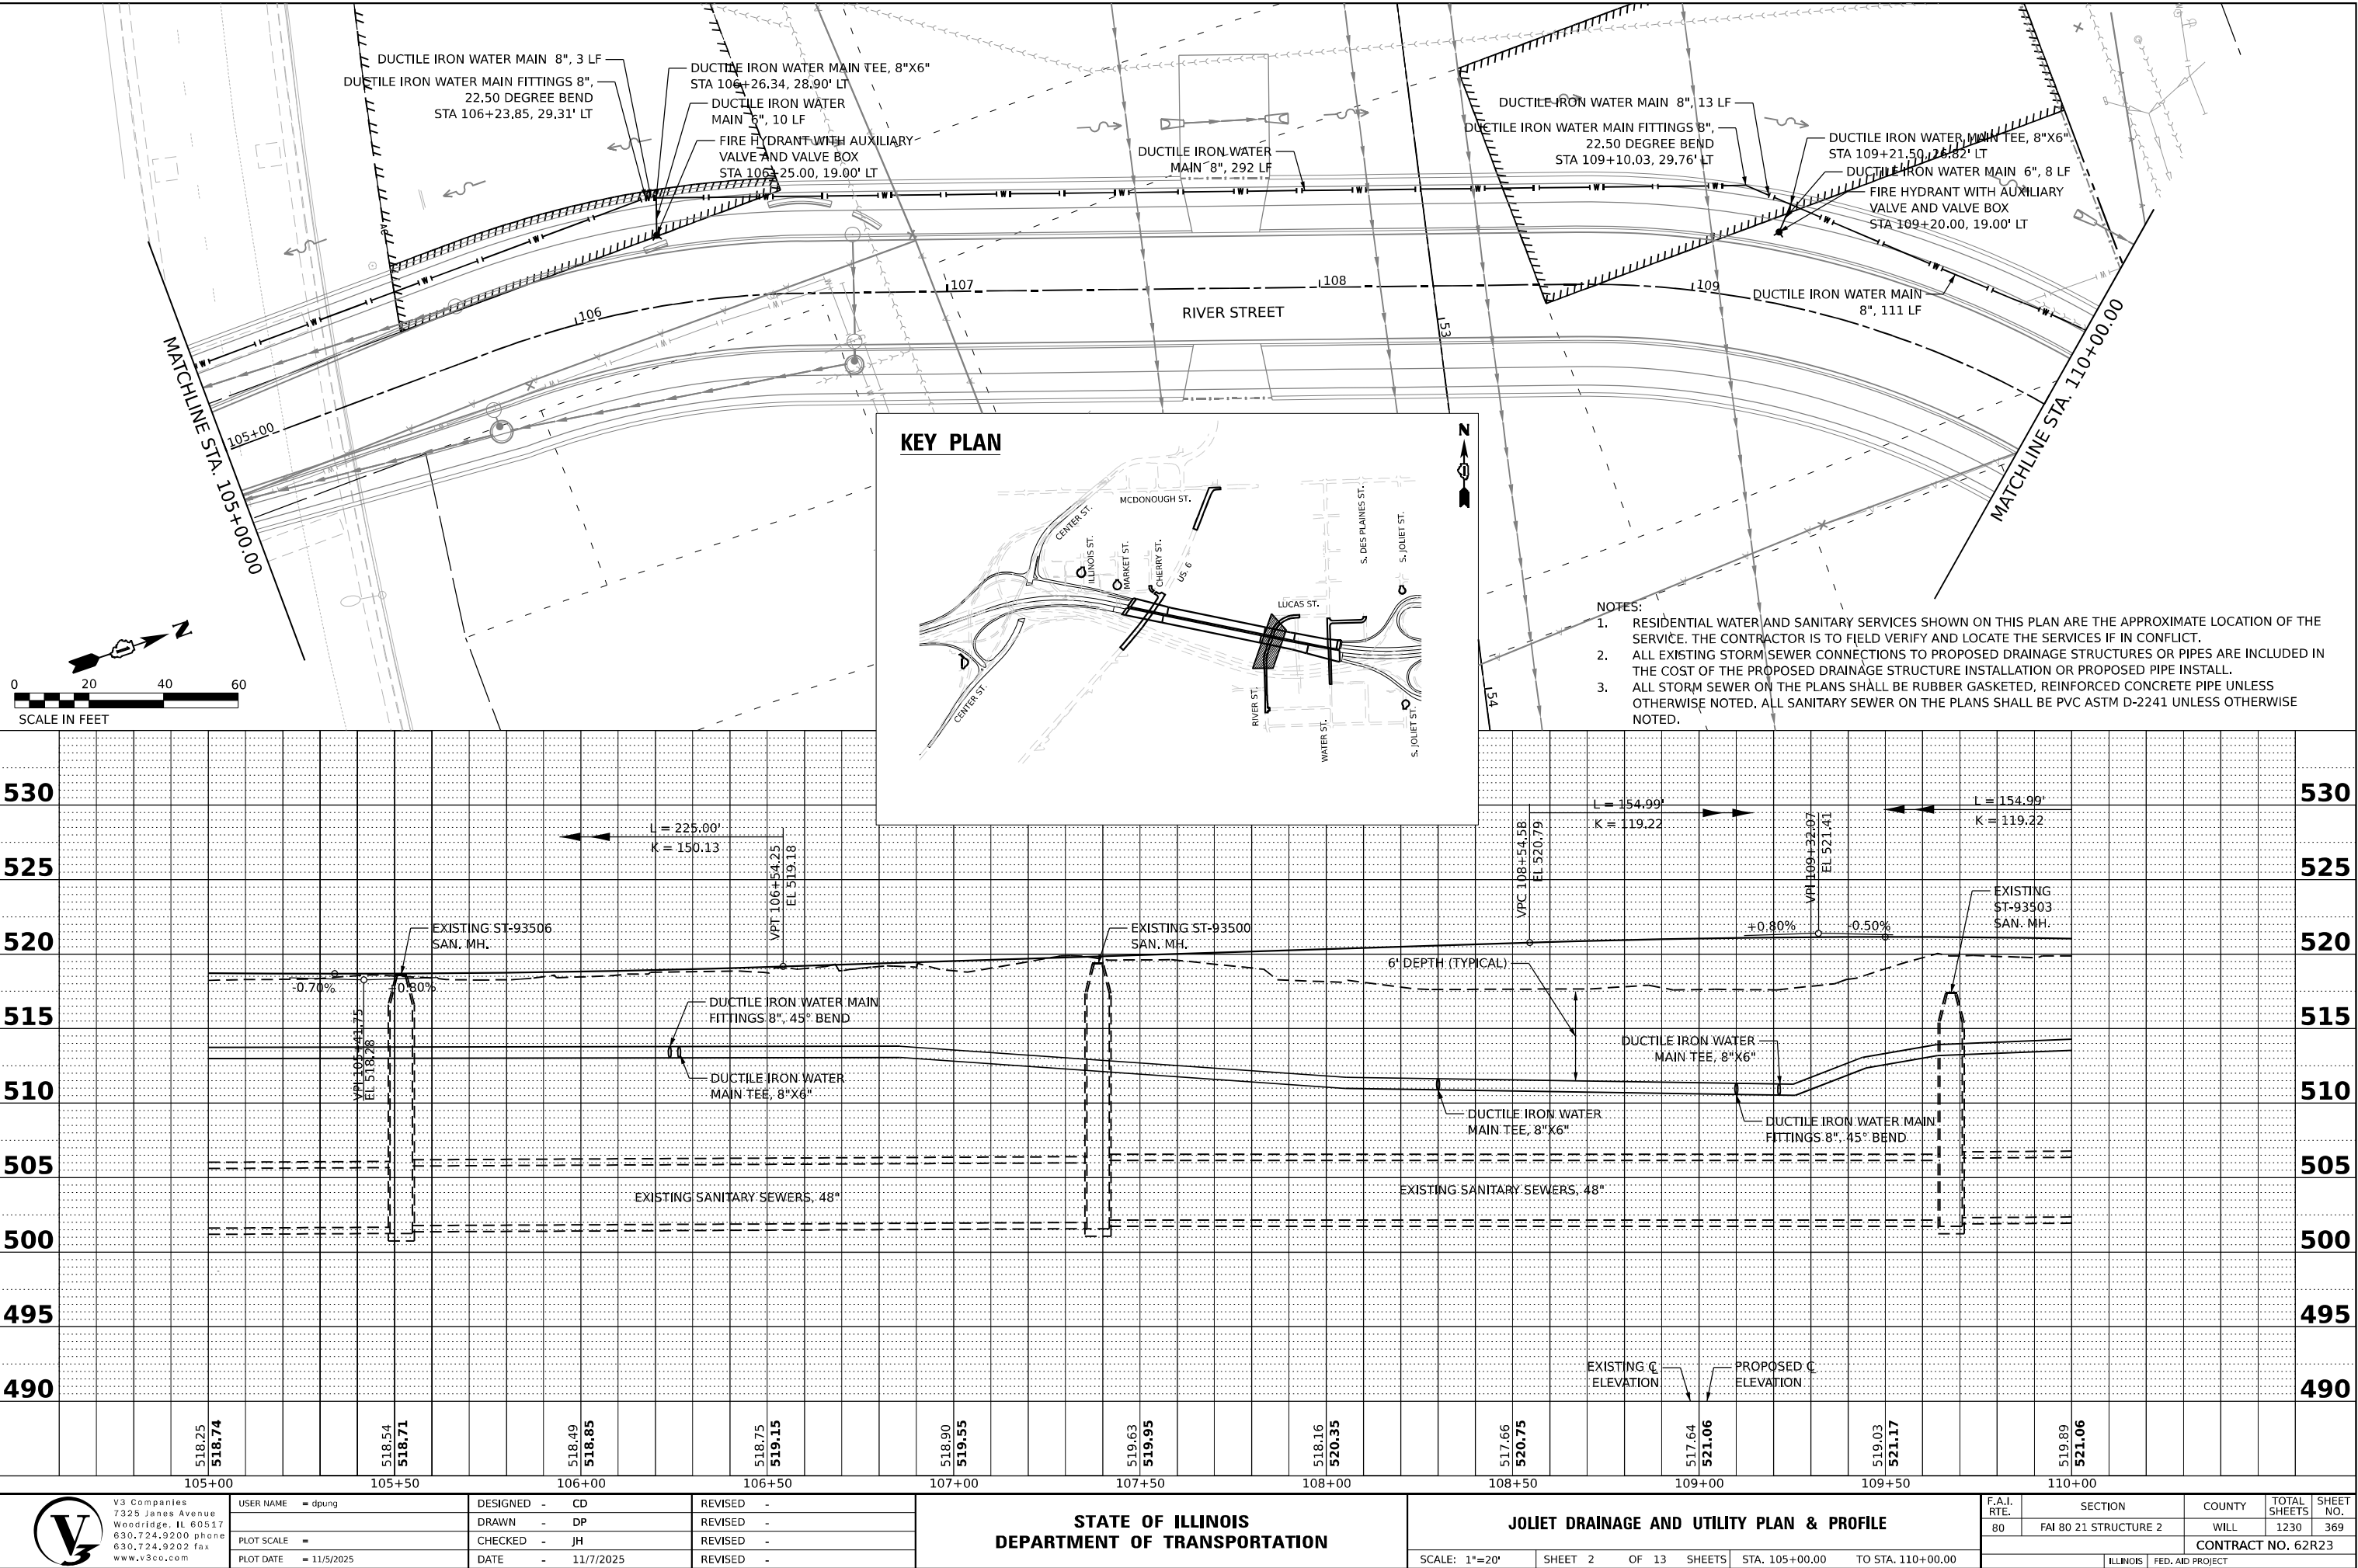

V3 Companies
7325 Janes Avenue
Woodridge, IL 60517
630.724.9200 phone
630.724.9202 fax
www.v3co.com

USER NAME = dpung	DESIGNED - CD	REVISED -
PLOT SCALE =	DRAWN - DP	REVISED -
PLOT DATE = 11/5/2025	CHECKED - JH	REVISED -
	DATE - 11/7/2025	REVISED -


STATE OF ILLINOIS
DEPARTMENT OF TRANSPORTATION

JOLIET DRAINAGE AND UTILITY PLAN & PROFILE

SCALE: 1"=20' SHEET 2 OF 13 SHEETS STA. 105+00.00 TO STA. 110+00.00

F.A.I. RTE.	SECTION	COUNTY	TOTAL SHEETS	SHEET NO.
80	FAI 80 21 STRUCTURE 2	WILL	1230	369
CONTRACT NO. 62R23				
ILLINOIS FED. AID PROJECT				


PROFILE	SURVEYED _____	BY _____	DATE _____
	PLOTTED _____ GRADES CHECKED _____ B.M. NOTED _____ STRUCTURE NOTATIONS CH'KD _____		
NOTE BOOK _____			
NO. _____			

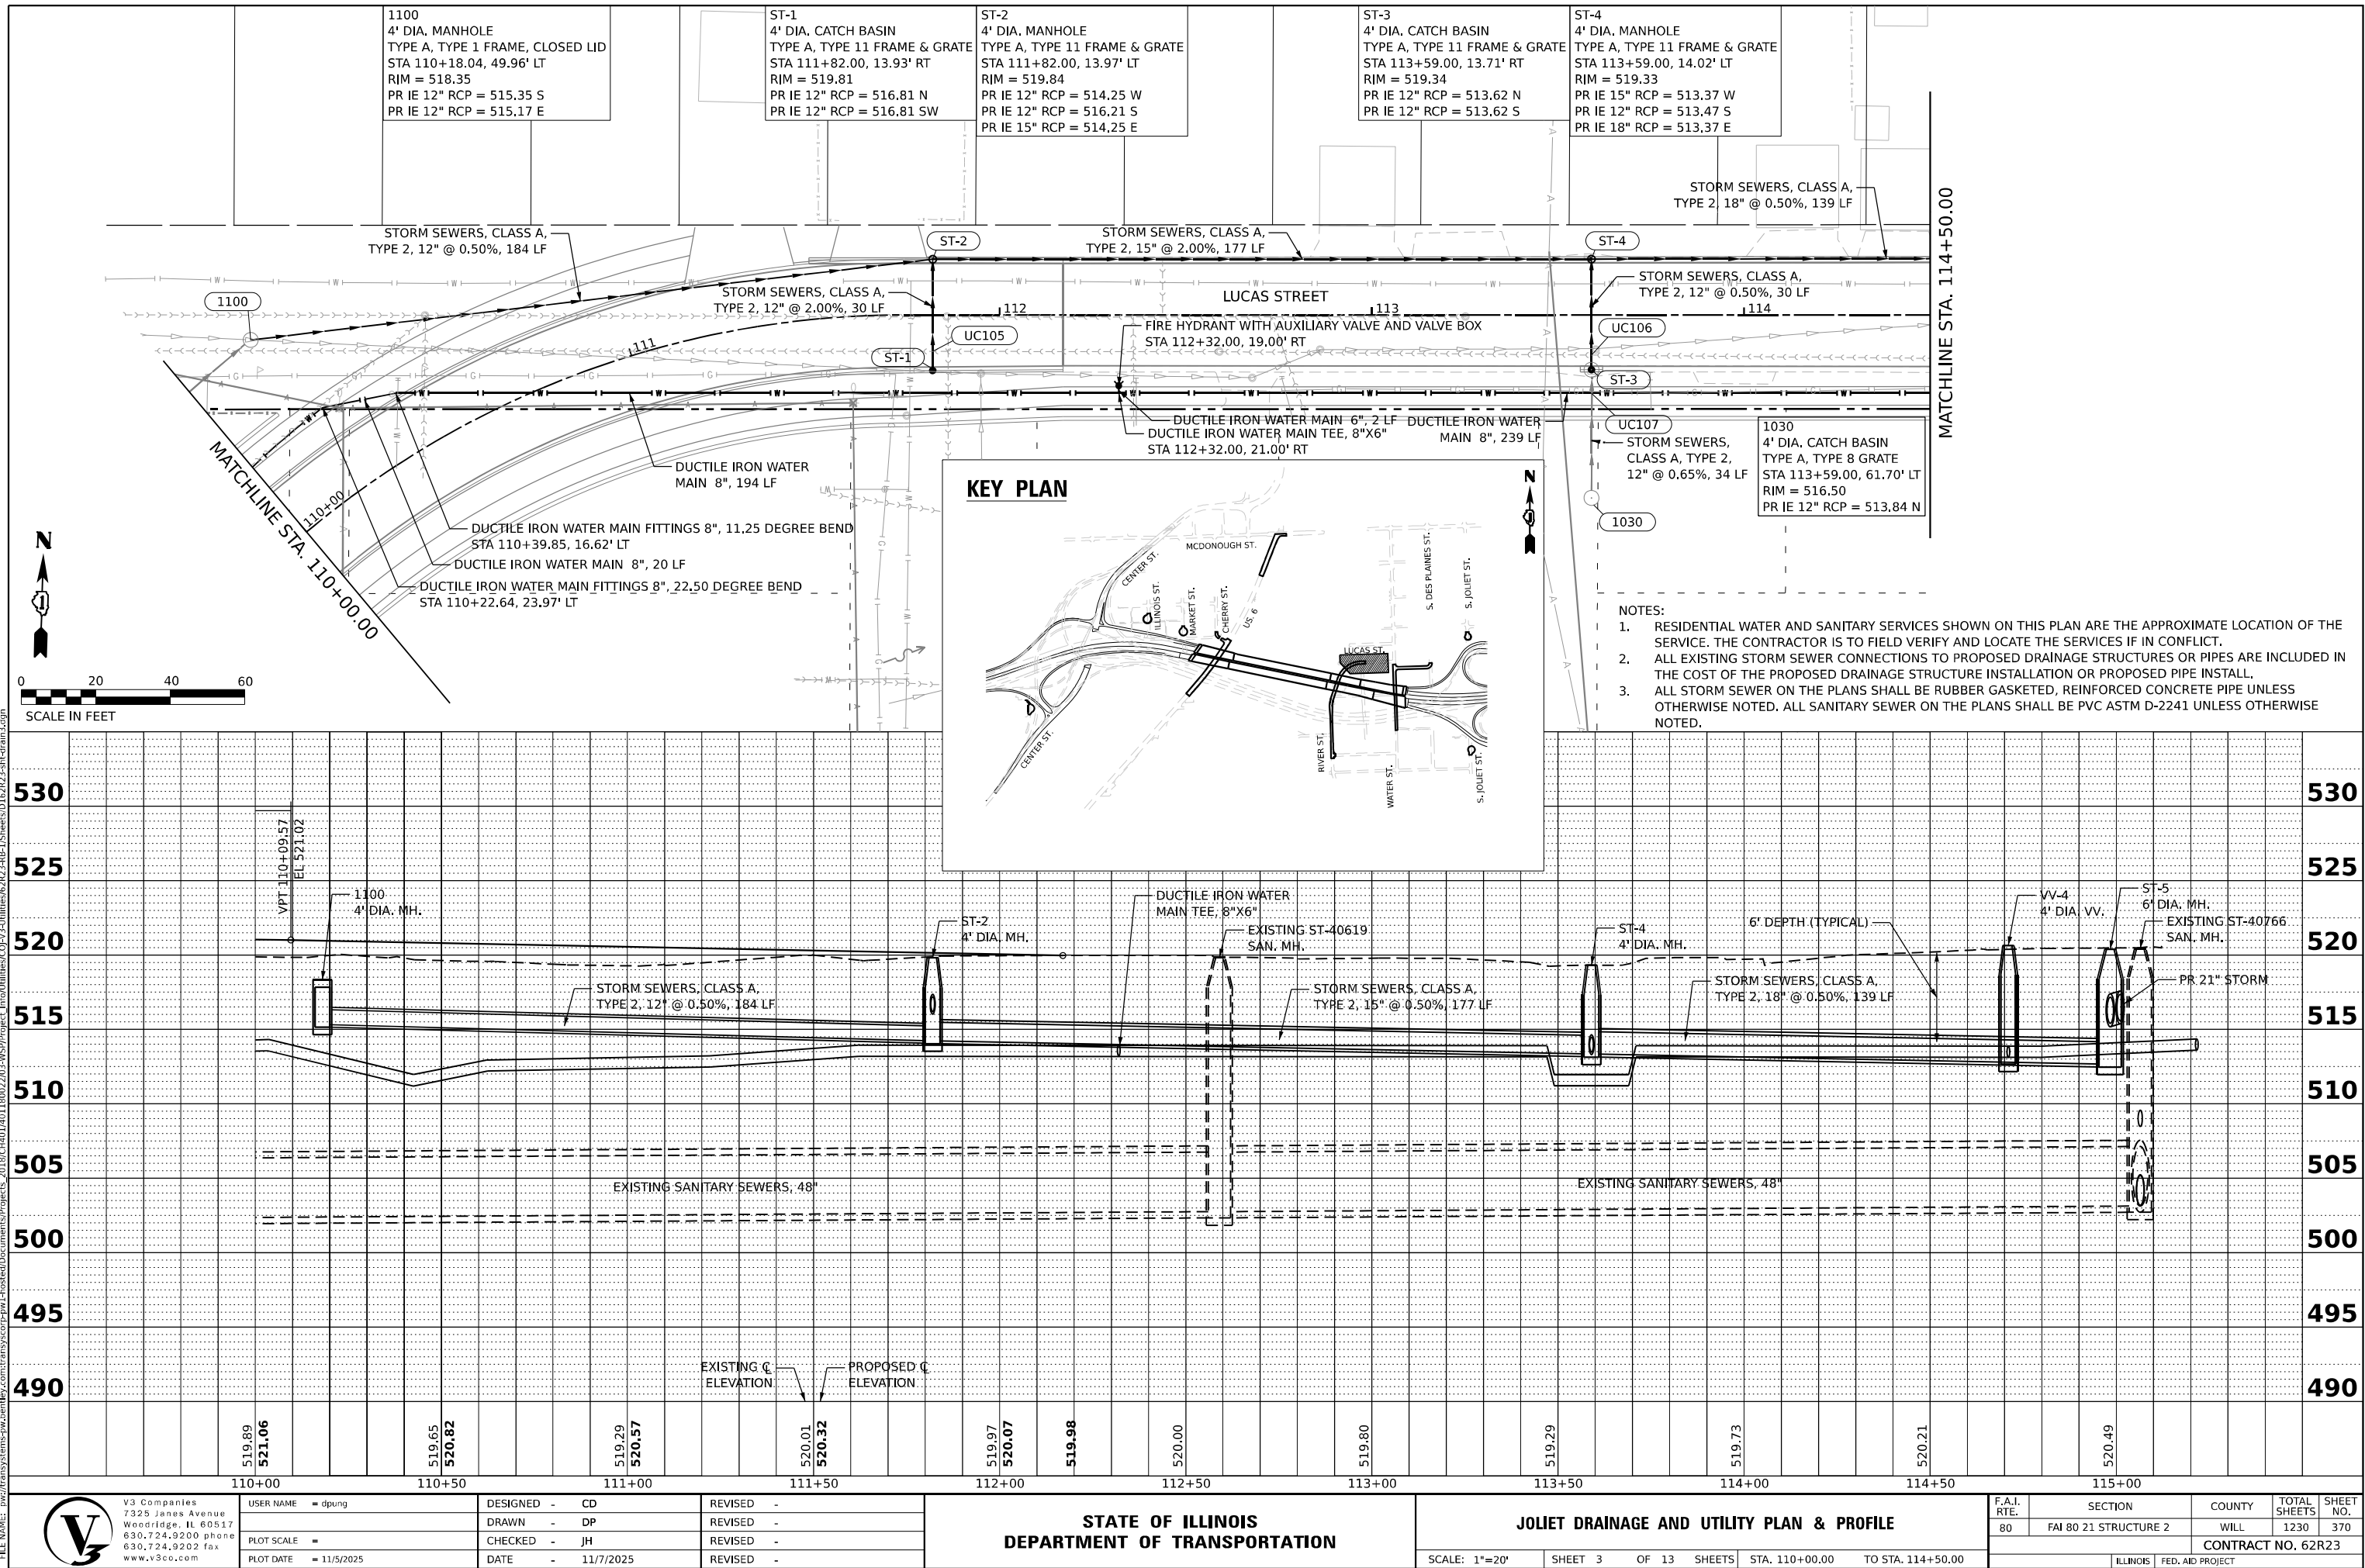

PLAN	SURVEYED PLOTTED ALIGNMENT CHECKED CADD FILE NAME	BY	DATE
NOTE BOOK NO.			

PROFILE	SURVEYED PLOTTED GRADES CHECKED STRUCTURE NOTATIONS CHECKED	BY	DATE
NOTE BOOK NO.			

MODEL Default
FILE NAME: p:\v3\transystems-pw\jenkey.com\transys\corp-pw\1\shared\Documents\Projects_2018\CH401\401180022\03-VS97\project_Info\Utilities\CO-VS-Utilities\62R23-4B-1\Sheets\62R23-sh-drain4.dgn

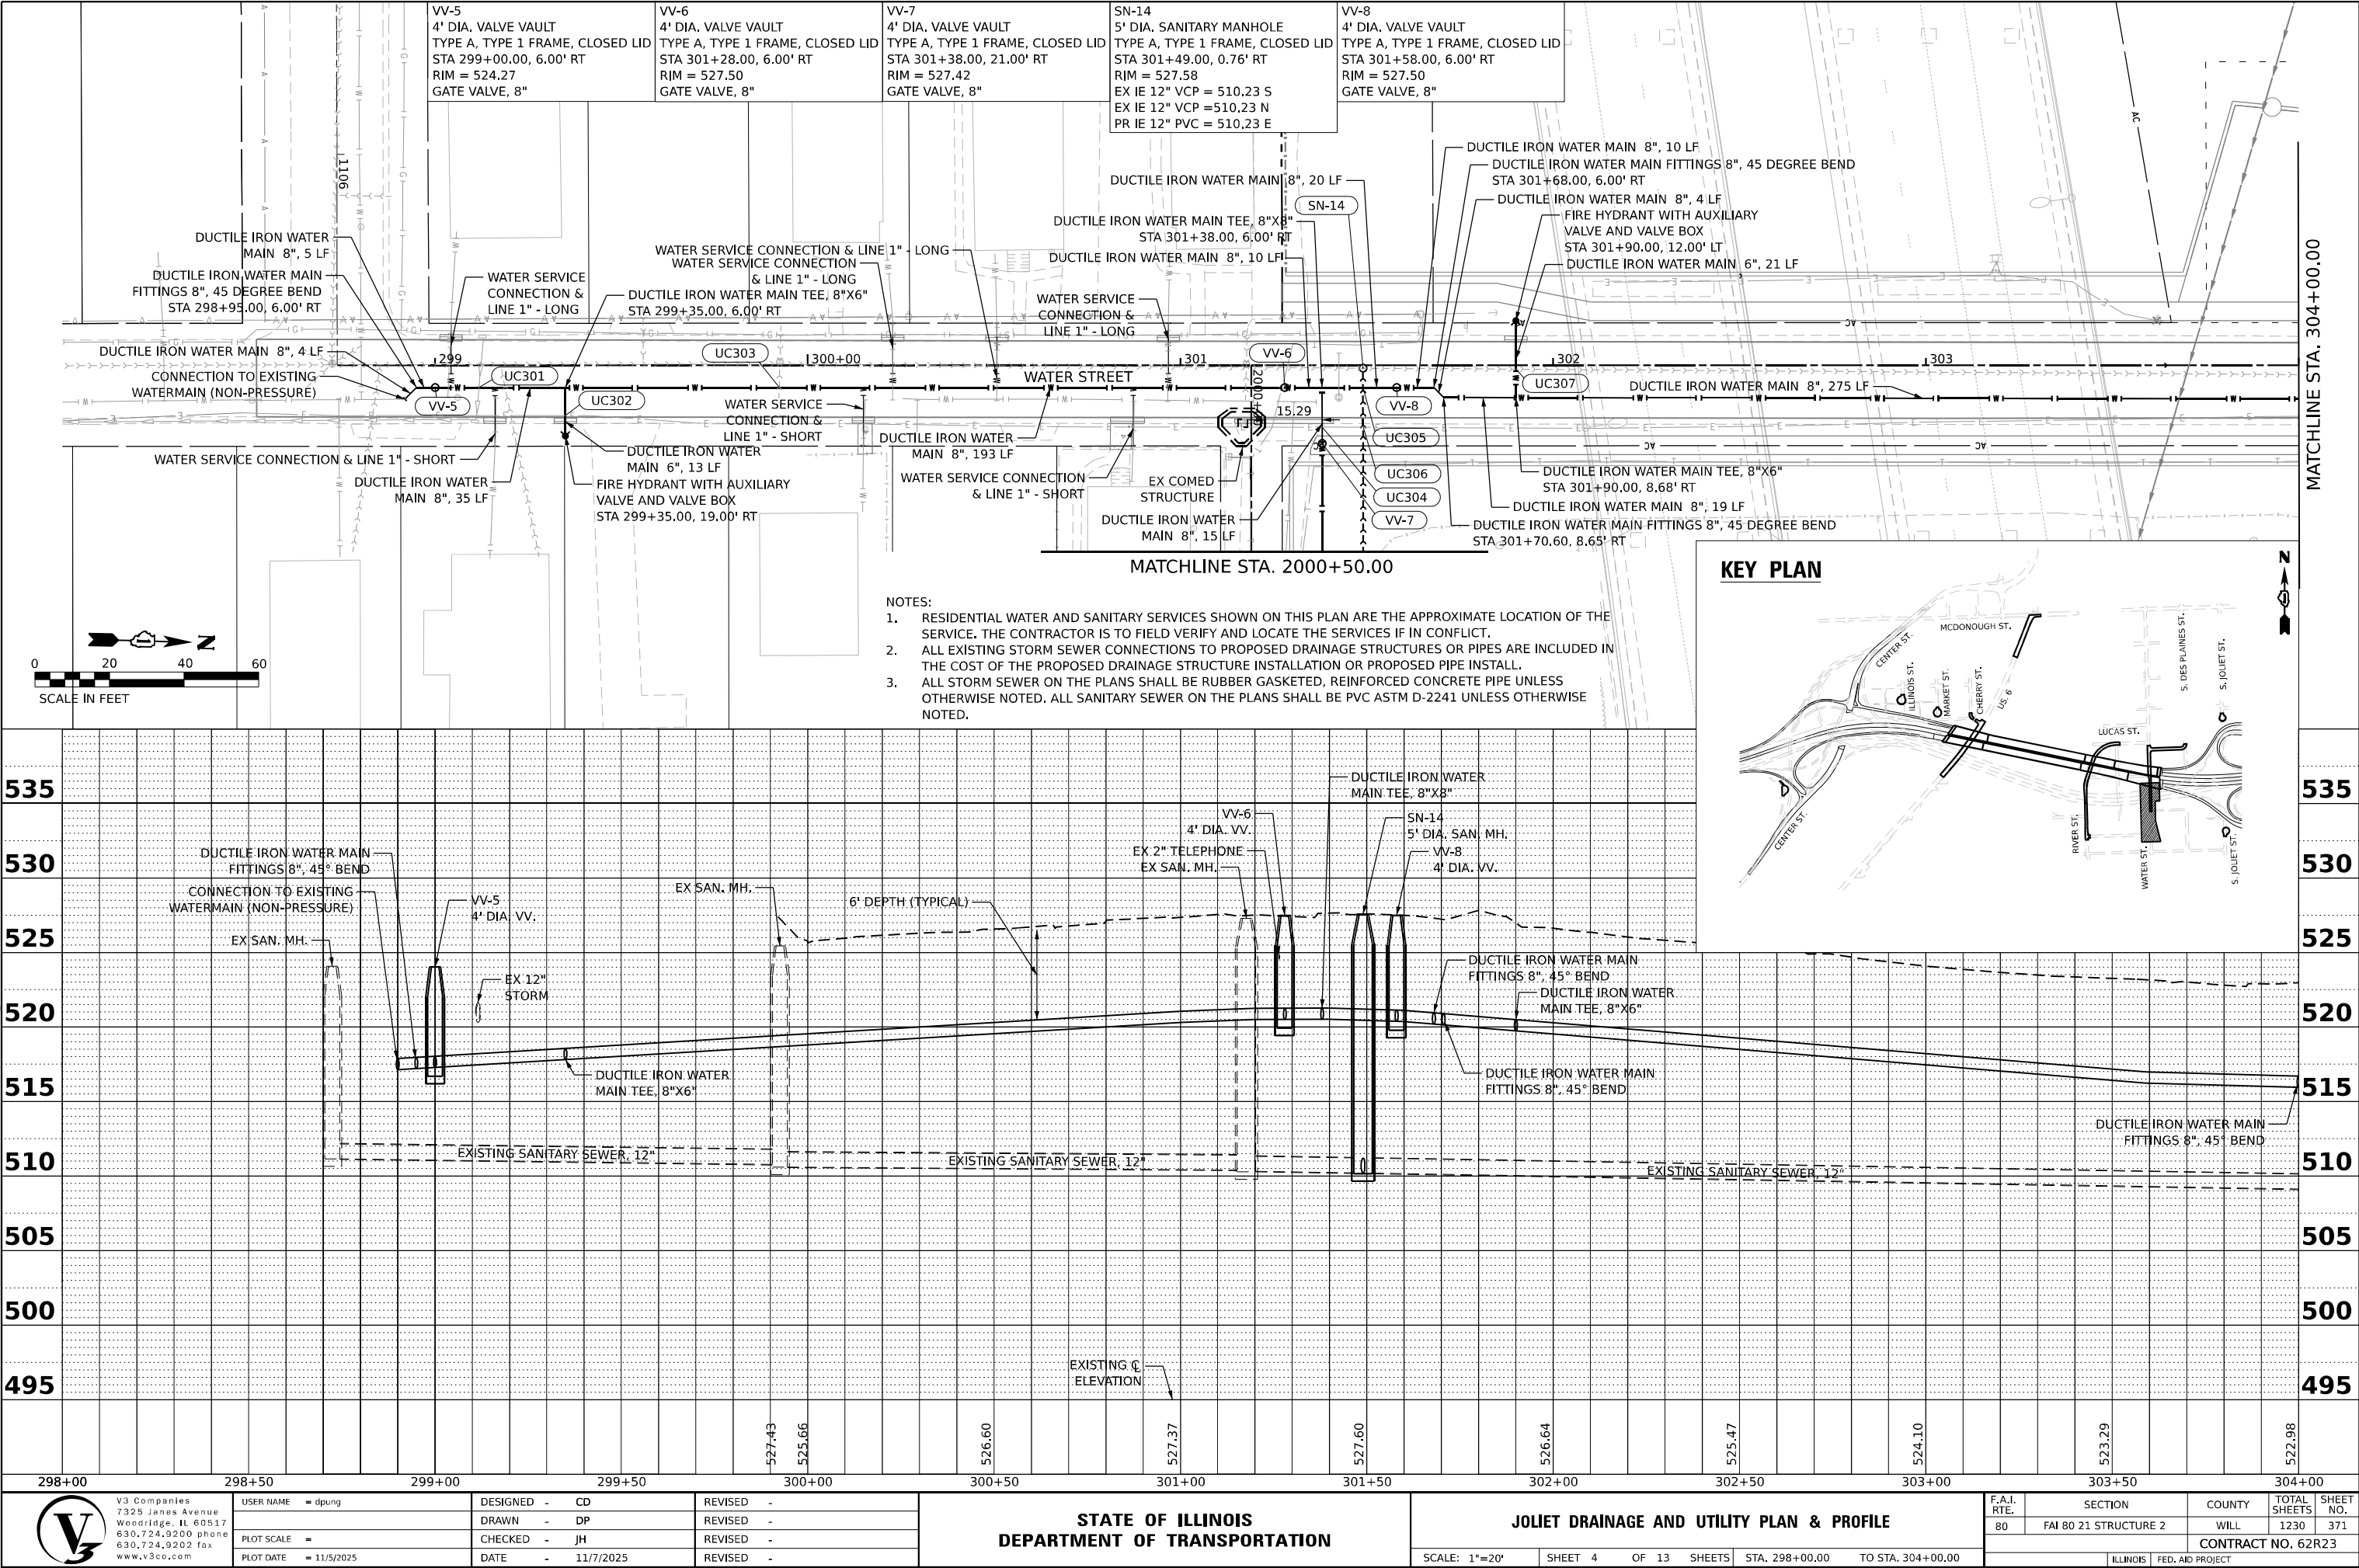

PROFILE	SURVEYED _____	BY _____	DATE _____
	PLOTTED _____		
NOTE BOOK _____	GRADES CHECKED _____		
NO. _____	ILLU. NOTED _____		
	STRUCTURE NOTATIONS CH'KO _____		

Matchline Sta. 304+00.00

Matchline Sta. 400+50.00

KEY PLAN

NOTES:

1. RESIDENTIAL WATER AND SANITARY SERVICES SHOWN ON THIS PLAN ARE THE APPROXIMATE LOCATION OF THE CONTRACTOR IS TO FIELD VERIFY AND LOCATE THE SERVICES IF IN CONFLICT.
2. ALL EXISTING STORM SEWER CONNECTIONS TO PROPOSED DRAINAGE STRUCTURES OR PIPES ARE INCLUDED IN PROPOSED DRAINAGE STRUCTURE INSTALLATION OR PROPOSED PIPE INSTALL.
3. ALL STORM SEWER ON THE PLANS SHALL BE RUBBER GASKETED, REINFORCED CONCRETE PIPE UNLESS OTHERWISE NOTED. SANITARY SEWER ON THE PLANS SHALL BE PVC ASTM D-2241 UNLESS OTHERWISE NOTED.

MATCHLINE STA. 114+50.00

1900
4' DIA. MANHOLE
TYPE A, TYPE 1 FRAME, CLOSED LID
STA 306+99.29, 4.10' LT
RIM = 520.01
EX IE 12" RCP = 516.07 S
PR IE 18" RCP = 516.07 N
PR IE 15" RCP = 516.07 E

ST-7
4' DIA. CATCH BASIN
TYPE A, TYPE 11 FRAME & GRATE
STA 307+94.74, 22.67' LT
RIM = 520.36
PR IE 12" RCP = 517.36 N

SN-1
4' DIA. SANITARY MANHOLE
TYPE A, TYPE 1 FRAME, CLOSED LID
STA 304+75.35, 3.02' RT
RIM = 522.32
EX IE 12" VCP = 508.82 S
PR IE 12" RCP = 508.80 N

VV-10
4' DIA. VALVE VAULT
TYPE A, TYPE 1 FRAME, CLOSED LID
STA 400+25.00, 5.00' RT
RIM = 520.98
GATE VALVE, 8"

SN-2
5' DIA. SANITARY MANHOLE
TYPE A, TYPE 1 FRAME, CLOSED LID
STA 307+51.73, 3.00' RT
RIM = 520.69
PR IE 24" RCP = 507.29 N
PR IE 12" RCP = 507.29 S
PR IE 24" RCP = 507.29 E

VV-9
4' DIA. VALVE VAULT
TYPE A, TYPE 1 FRAME, CLOSED LID
STA 307+24.00, 9.00' RT
RIM = 520.70
GATE VALVE, 8"

SN-3
EX. 6' DIA. SANITARY MANHOLE
NEW TYPE A, TYPE 1 FRAME, CLOSED LID
STA 307+99.42, 5.75' LT
RIM = 520.41
EX IE 48" RCP = ±503.15 N
EX IE 48" RCP = ±503.15 W
PR IE 24" RCP = 507.17 S
PR IE 24" RCP = 508.54 N

VV-11
4' DIA. VALVE VAULT
TYPE A, TYPE 1 FRAME, CLOSED LID
STA 307+62.00, 9.10' RT
RIM = 520.53
GATE VALVE, 8"

ST-5
5' DIA. MANHOLE
TYPE A, TYPE 1 FRAME, CLOSED LID
STA 308+26.75, 13.94' LT
RIM = 520.40
PR IE 18" RCP = 512.68 W
PR IE 12" RCP = 515.43 SW
PR IE 18" RCP = 515.43 S
PR IE 24" RCP = 512.68 N

ST-6
4' DIA. MANHOLE
TYPE A, TYPE 1 FRAME, CLOSED LID
STA 308+09.32, 12.24' LT
RIM = 520.40
EX IE 12" RCP = 516.17 E
EX IE 12" RCP = 515.96 W
EX IE 24" RCP = 512.31 N
PR IE 24" RCP = 512.56 S

ST-7
4' DIA. CATCH BASIN
TYPE A, TYPE 11 FRAME & GRATE
STA 307+94.74, 22.67' LT
RIM = 520.36
PR IE 12" RCP = 517.36 N

SN-4
5' DIA. SANITARY MANHOLE
TYPE A, TYPE 1 FRAME, CLOSED LID
STA 308+10.99, 1.68' RT
RIM = 520.44
EX IE 24" RCP = 508.67 N
PR IE 24" RCP = 508.61 S

ST-5
5' DIA. MANHOLE
TYPE A, TYPE 1 FRAME, CLOSED LID
STA 308+26.75, 13.94' LT
RIM = 520.40
PR IE 18" RCP = 512.68 W
PR IE 12" RCP = 515.43 SW
PR IE 18" RCP = 515.43 S
PR IE 24" RCP = 512.68 N

ST-6
4' DIA. MANHOLE
TYPE A, TYPE 1 FRAME, CLOSED LID
STA 308+09.32, 12.24' LT
RIM = 520.40
EX IE 12" RCP = 516.17 E
EX IE 12" RCP = 515.96 W
EX IE 24" RCP = 512.31 N
PR IE 24" RCP = 512.56 S

ST-7
4' DIA. CATCH BASIN
TYPE A, TYPE 11 FRAME & GRATE
STA 307+94.74, 22.67' LT
RIM = 520.36
PR IE 12" RCP = 517.36 N

SN-1
4' DIA. SANITARY MANHOLE
TYPE A, TYPE 1 FRAME, CLOSED LID
STA 304+75.35, 3.02' RT
RIM = 522.32
EX IE 12" VCP = 508.82 S
PR IE 12" RCP = 508.80 N

VV-10
4' DIA. VALVE VAULT
TYPE A, TYPE 1 FRAME, CLOSED LID
STA 400+25.00, 5.00' RT
RIM = 520.98
GATE VALVE, 8"

SN-2
5' DIA. SANITARY MANHOLE
TYPE A, TYPE 1 FRAME, CLOSED LID
STA 307+51.73, 3.00' RT
RIM = 520.69
PR IE 24" RCP = 507.29 N
PR IE 12" RCP = 507.29 S
PR IE 24" RCP = 507.29 E

VV-9
4' DIA. VALVE VAULT
TYPE A, TYPE 1 FRAME, CLOSED LID
STA 307+24.00, 9.00' RT
RIM = 520.70
GATE VALVE, 8"

SN-3
EX. 6' DIA. SANITARY MANHOLE
NEW TYPE A, TYPE 1 FRAME, CLOSED LID
STA 307+99.42, 5.75' LT
RIM = 520.41
EX IE 48" RCP = ±503.15 N
EX IE 48" RCP = ±503.15 W
PR IE 24" RCP = 507.17 S
PR IE 24" RCP = 508.54 N

VV-11
4' DIA. VALVE VAULT
TYPE A, TYPE 1 FRAME, CLOSED LID
STA 307+62.00, 9.10' RT
RIM = 520.53
GATE VALVE, 8"

ST-5
5' DIA. MANHOLE
TYPE A, TYPE 1 FRAME, CLOSED LID
STA 308+26.75, 13.94' LT
RIM = 520.40
PR IE 18" RCP = 512.68 W
PR IE 12" RCP = 515.43 SW
PR IE 18" RCP = 515.43 S
PR IE 24" RCP = 512.68 N

ST-6
4' DIA. MANHOLE
TYPE A, TYPE 1 FRAME, CLOSED LID
STA 308+09.32, 12.24' LT
RIM = 520.40
EX IE 12" RCP = 516.17 E
EX IE 12" RCP = 515.96 W
EX IE 24" RCP = 512.31 N
PR IE 24" RCP = 512.56 S

ST-7
4' DIA. CATCH BASIN
TYPE A, TYPE 11 FRAME & GRATE
STA 307+94.74, 22.67' LT
RIM = 520.36
PR IE 12" RCP = 517.36 N

SN-4
5' DIA. SANITARY MANHOLE
TYPE A, TYPE 1 FRAME, CLOSED LID
STA 308+10.99, 1.68' RT
RIM = 520.44
EX IE 24" RCP = 508.67 N
PR IE 24" RCP = 508.61 S

ST-5
5' DIA. MANHOLE
TYPE A, TYPE 1 FRAME, CLOSED LID
STA 308+26.75, 13.94' LT
RIM = 520.40
PR IE 18" RCP = 512.68 W
PR IE 12" RCP = 515.43 SW
PR IE 18" RCP = 515.43 S
PR IE 24" RCP = 512.68 N

ST-6
4' DIA. MANHOLE
TYPE A, TYPE 1 FRAME, CLOSED LID
STA 308+09.32, 12.24' LT
RIM = 520.40
EX IE 12" RCP = 516.17 E
EX IE 12" RCP = 515.96 W
EX IE 24" RCP = 512.31 N
PR IE 24" RCP = 512.56 S

ST-7
4' DIA. CATCH BASIN
TYPE A, TYPE 11 FRAME & GRATE
STA 307+94.74, 22.67' LT
RIM = 520.36
PR IE 12" RCP = 517.36 N

SN-1
4' DIA. SANITARY MANHOLE
TYPE A, TYPE 1 FRAME, CLOSED LID
STA 304+75.35, 3.02' RT
RIM = 522.32
EX IE 12" VCP = 508.82 S
PR IE 12" RCP = 508.80 N

VV-10
4' DIA. VALVE VAULT
TYPE A, TYPE 1 FRAME, CLOSED LID
STA 400+25.00, 5.00' RT
RIM = 520.98
GATE VALVE, 8"

SN-2
5' DIA. SANITARY MANHOLE
TYPE A, TYPE 1 FRAME, CLOSED LID
STA 307+51.73, 3.00' RT
RIM = 520.69
PR IE 24" RCP = 507.29 N
PR IE 12" RCP = 507.29 S
PR IE 24" RCP = 507.29 E



VV-9
4' DIA. VALVE VAULT
TYPE A, TYPE 1 FRAME, CLOSED LID
STA 307+24.00, 9.00' RT
RIM = 520.70
GATE VALVE, 8"

SN-3
EX. 6' DIA. SANITARY MANHOLE
NEW TYPE A, TYPE 1 FRAME, CLOSED LID
STA 307+99.42, 5.75' LT
RIM = 520.41
EX IE 48" RCP = ±503.15 N
EX IE 48" RCP = ±503.15 W
PR IE 24" RCP = 507.17 S
PR IE 24" RCP = 508.54 N

VV-11
4


0 20 40 60

SCALE IN FEET

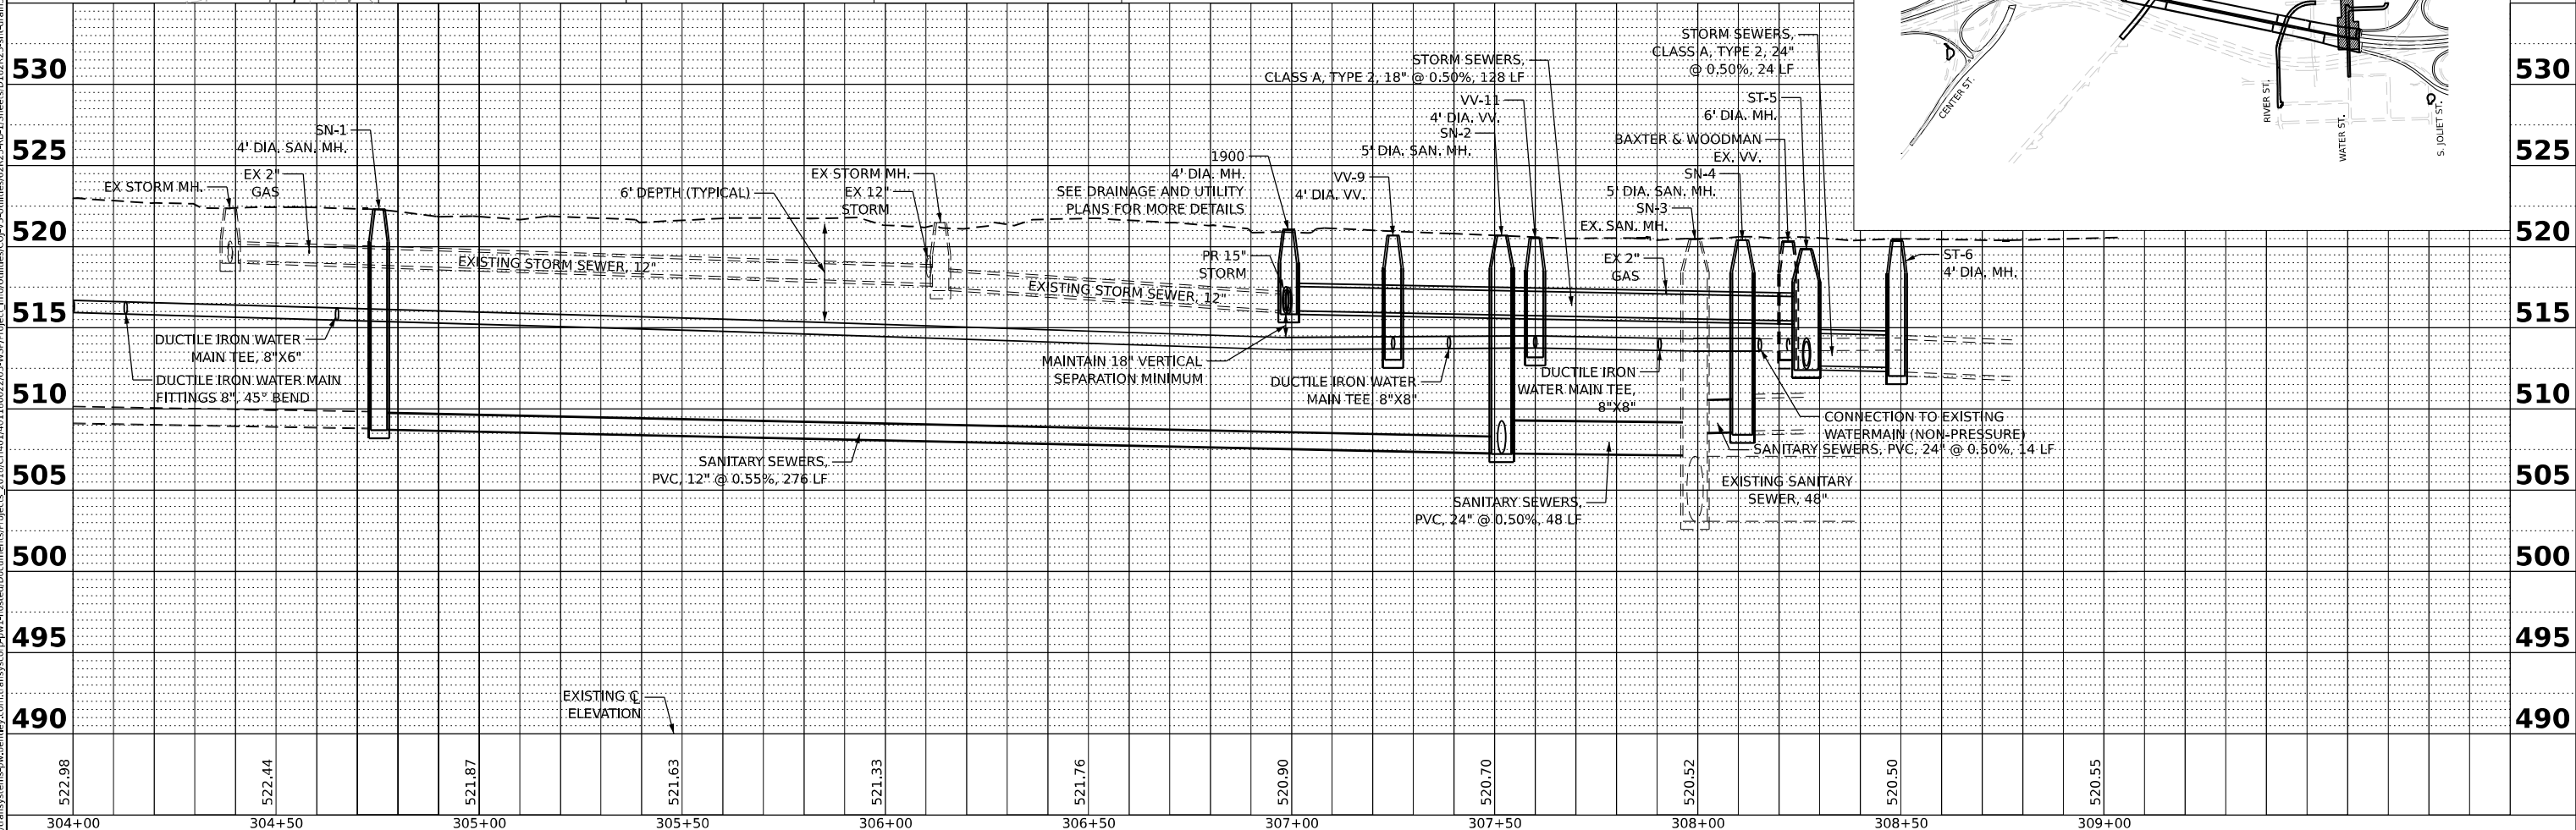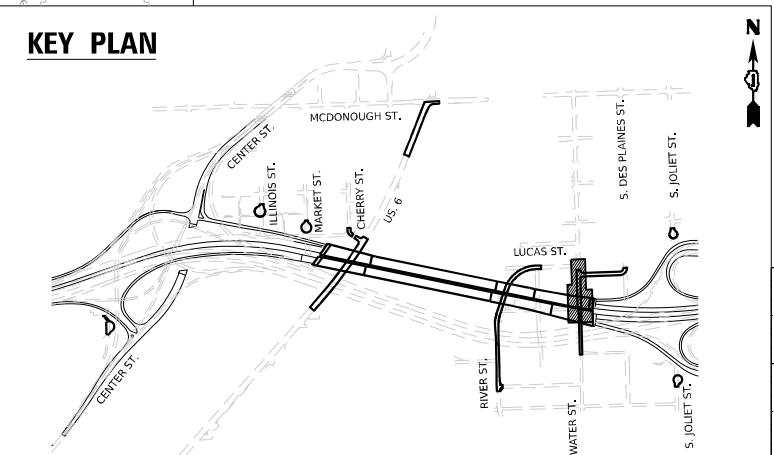

 V3 Companies 7325 James Avenue Woodridge, IL 60517 630.724.9200 phone 630.724.9202 fax www.v3co.com	USER NAME = dpung	DESIGNED - CD	REVISED -	STATE OF ILLINOIS DEPARTMENT OF TRANSPORTATION	JOLIET DRAINAGE AND UTILITY PLAN & PROFILE					F.A.I. RTE.	SECTION	COUNTY	TOTAL SHEETS	SHEET NO.
	PLOT SCALE =	DRAWN - DP	REVISED -							80	FAI 80 21 STRUCTURE 2	WILL	1230	372
	PLOT DATE = 11/5/2025	CHECKED - JH	REVISED -		CONTRACT NO. 62R23									
		DATE - 11/7/2025	REVISED -		SCALE: 1"=20' SHEET 5 OF 13 SHEETS STA. 304+00.00 TO STA. 309+00.00									



PROFILE	SURVEYED _____	BY _____	DATE _____
	PLOTTED _____		
	GRADES CHECKED _____		
	R.M., NOTED _____		
	STRUCTURE NOTATIONS CHECKED _____		
NOTE BOOK _____			
NO. _____			

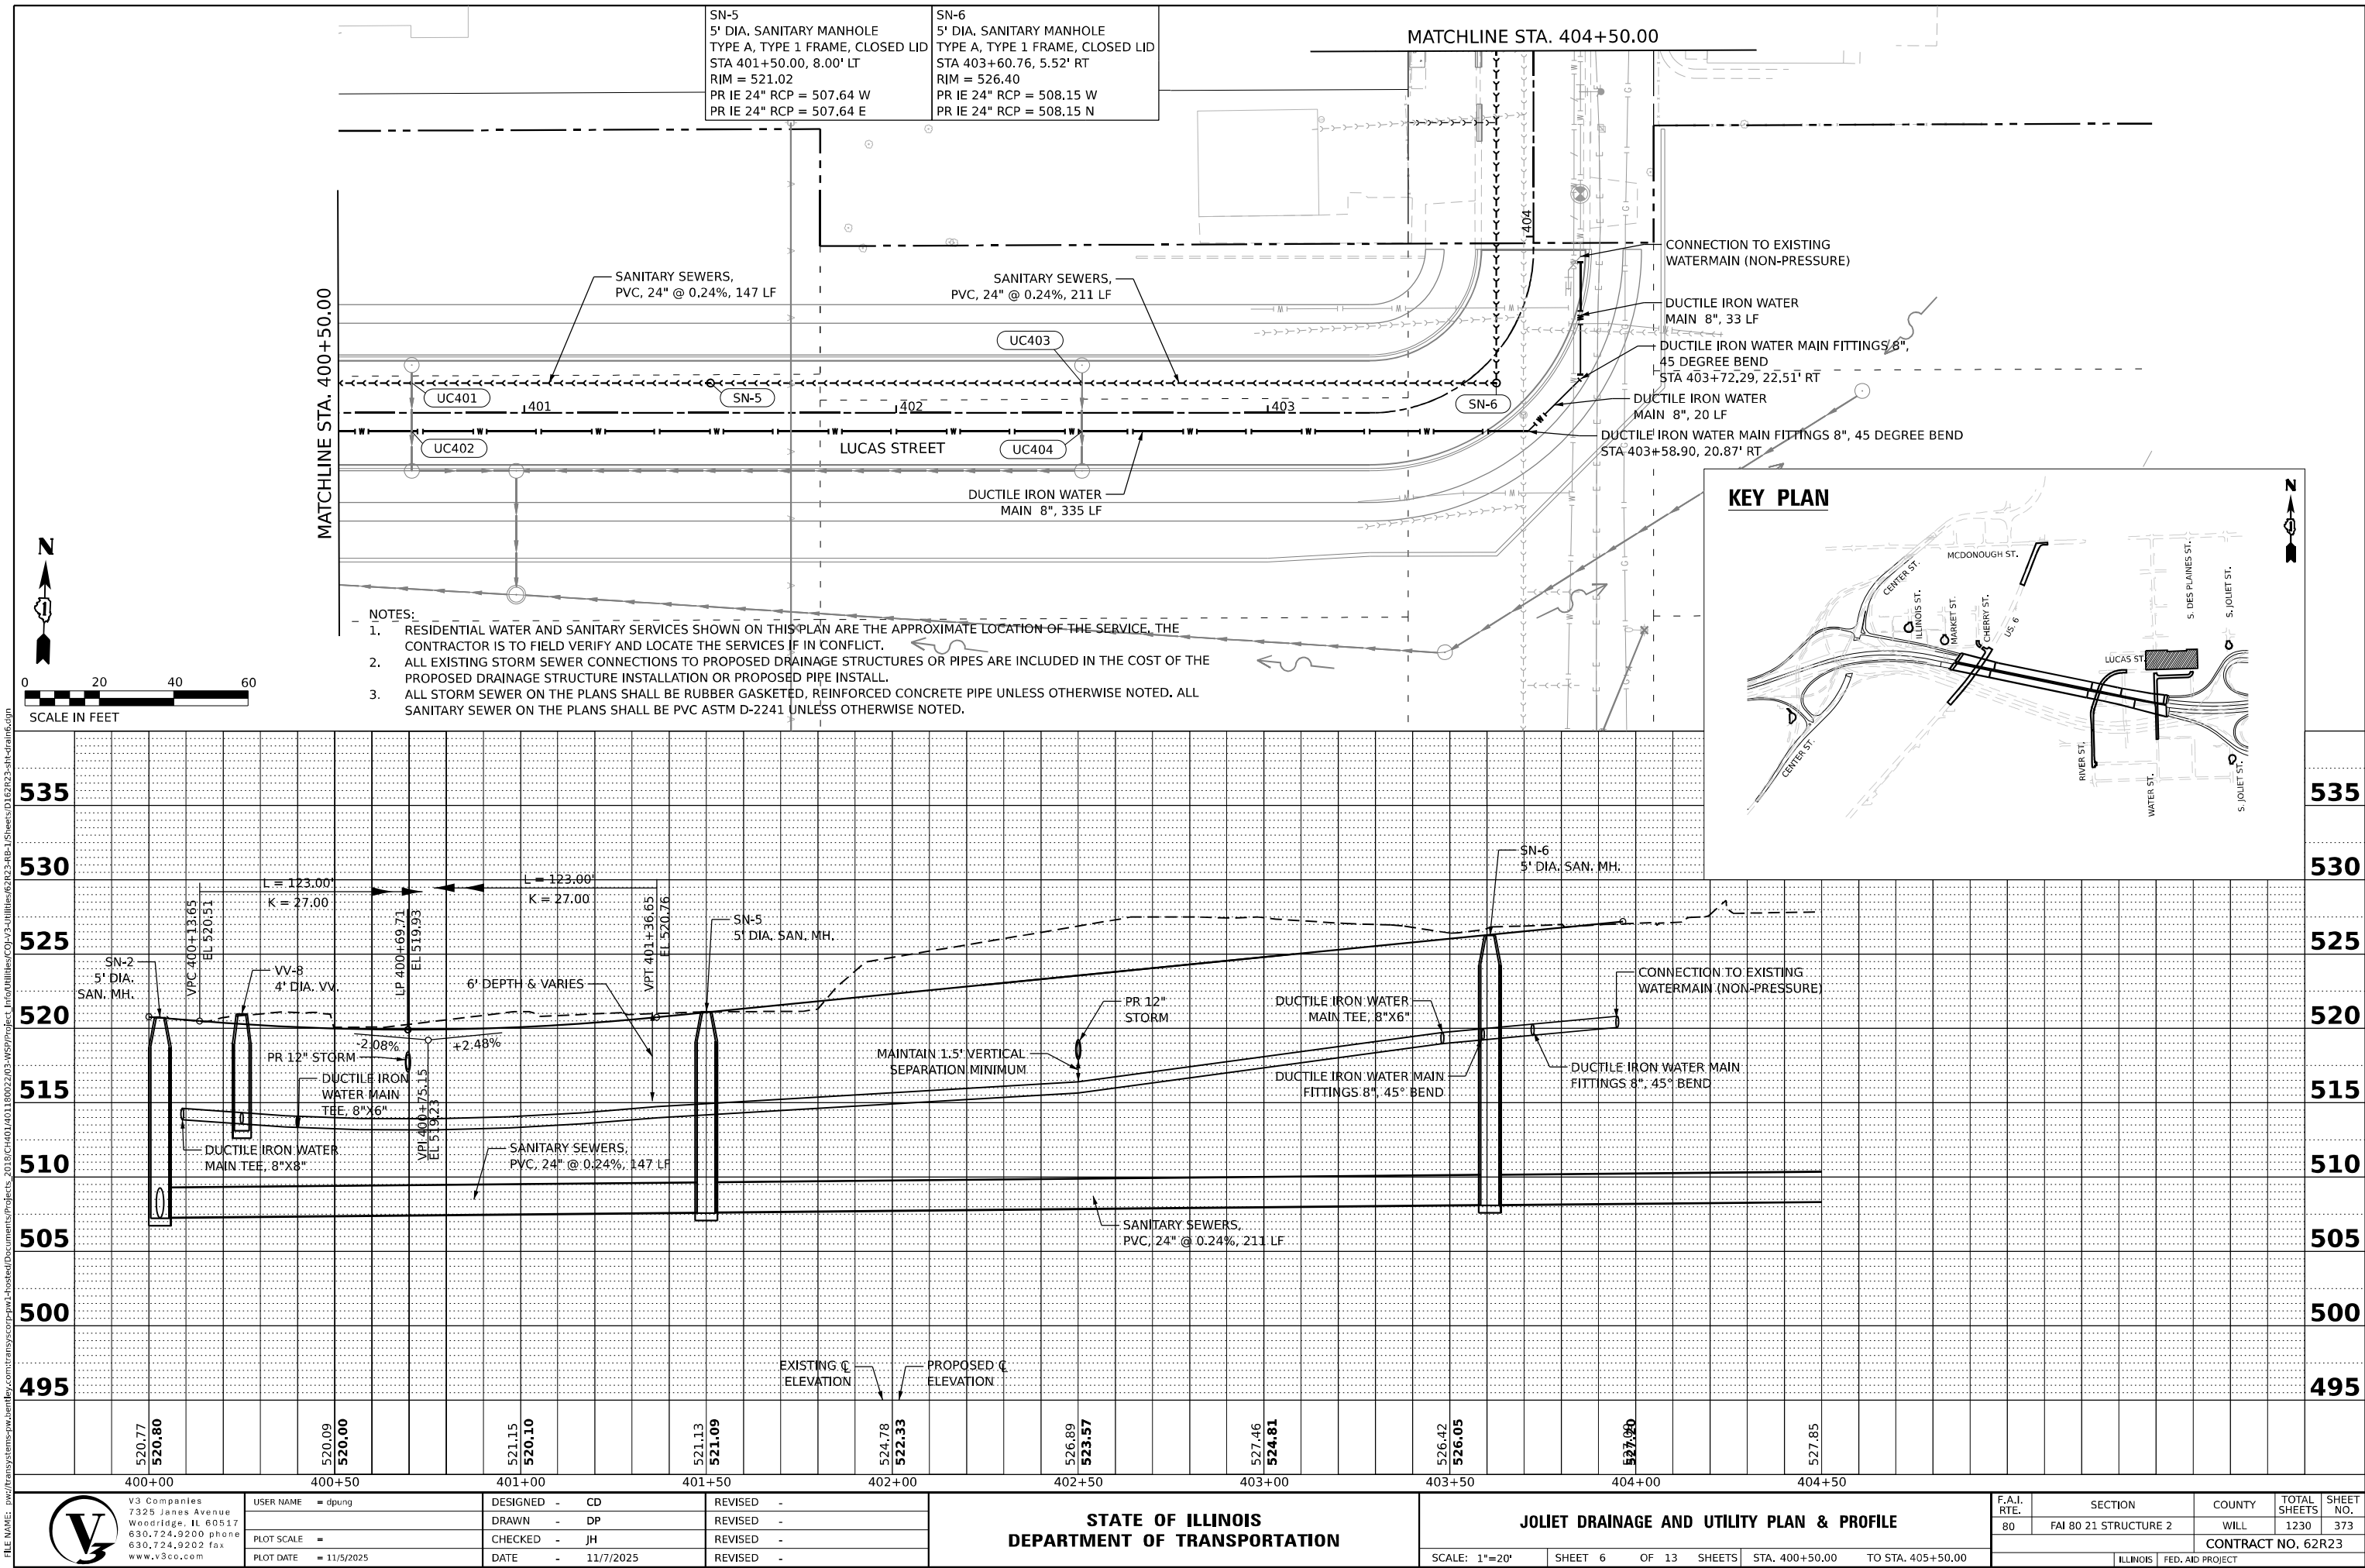


PLAN	SURVEYED	DATE
NO.	BY	
NOTE BOOK		
NO.		
NO.		

PROFILE	SURVEYED	DATE
NO.	BY	
NOTE BOOK		
NO.		
NO.		

MODEL: Default
FILE NAME: p:\v3\transystems-pw\jenkey.com\transyscorp-pw\1shared\Documents\Projects\2018\CH401\401180022\03-VS97\project_Info\Utilities\CO-VS-Utilities\62R23-4B-1\Sheets\0162R23-sh-train7.dgn

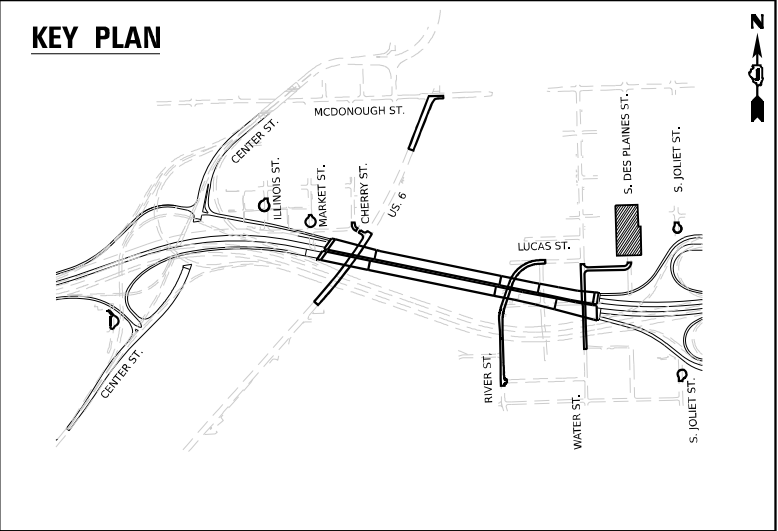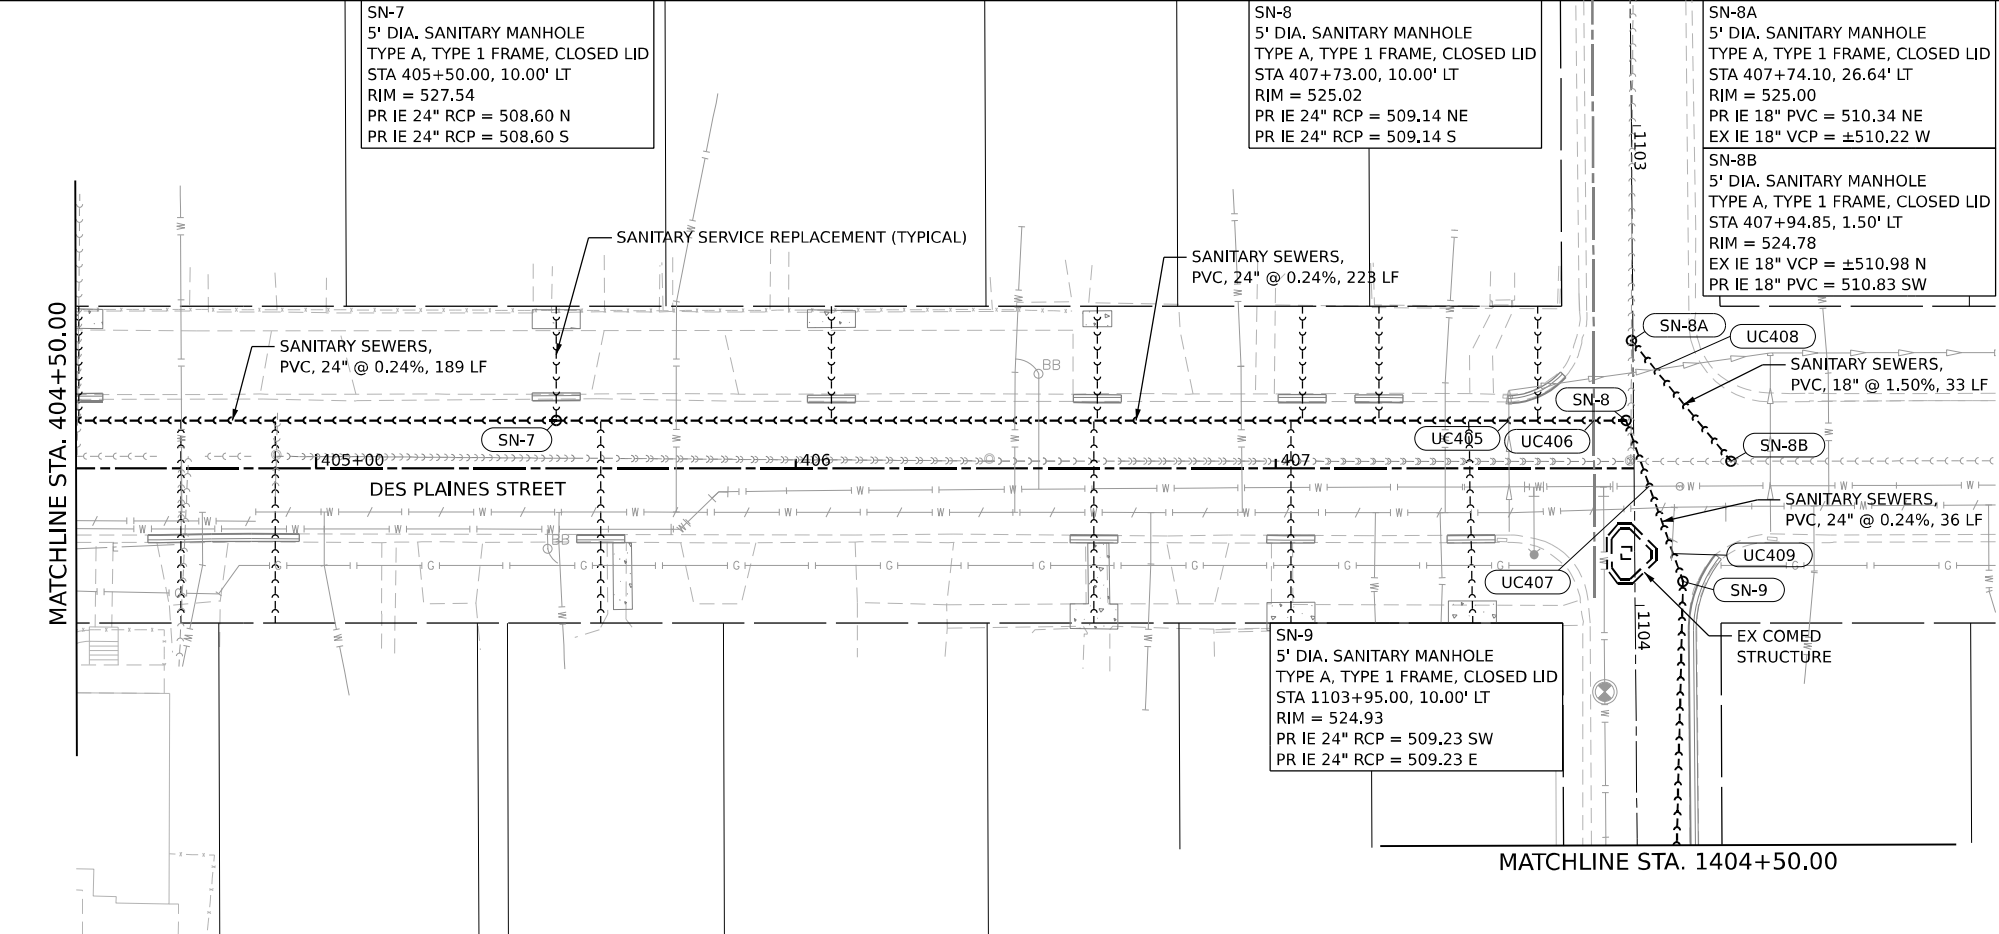

- NOTES:
1. RESIDENTIAL WATER AND SANITARY SERVICES SHOWN ON THIS PLAN ARE THE APPROXIMATE LOCATION OF THE SERVICE. THE CONTRACTOR IS TO FIELD VERIFY AND LOCATE THE SERVICES IF IN CONFLICT.
 2. ALL EXISTING STORM SEWER CONNECTIONS TO PROPOSED DRAINAGE STRUCTURES OR PIPES ARE INCLUDED IN THE COST OF THE PROPOSED DRAINAGE STRUCTURE INSTALLATION OR PROPOSED PIPE INSTALL.
 3. ALL STORM SEWER ON THE PLANS SHALL BE RUBBER GASKETED, REINFORCED CONCRETE PIPE UNLESS OTHERWISE NOTED. ALL SANITARY SEWER ON THE PLANS SHALL BE PVC ASTM D-2241 UNLESS OTHERWISE NOTED.

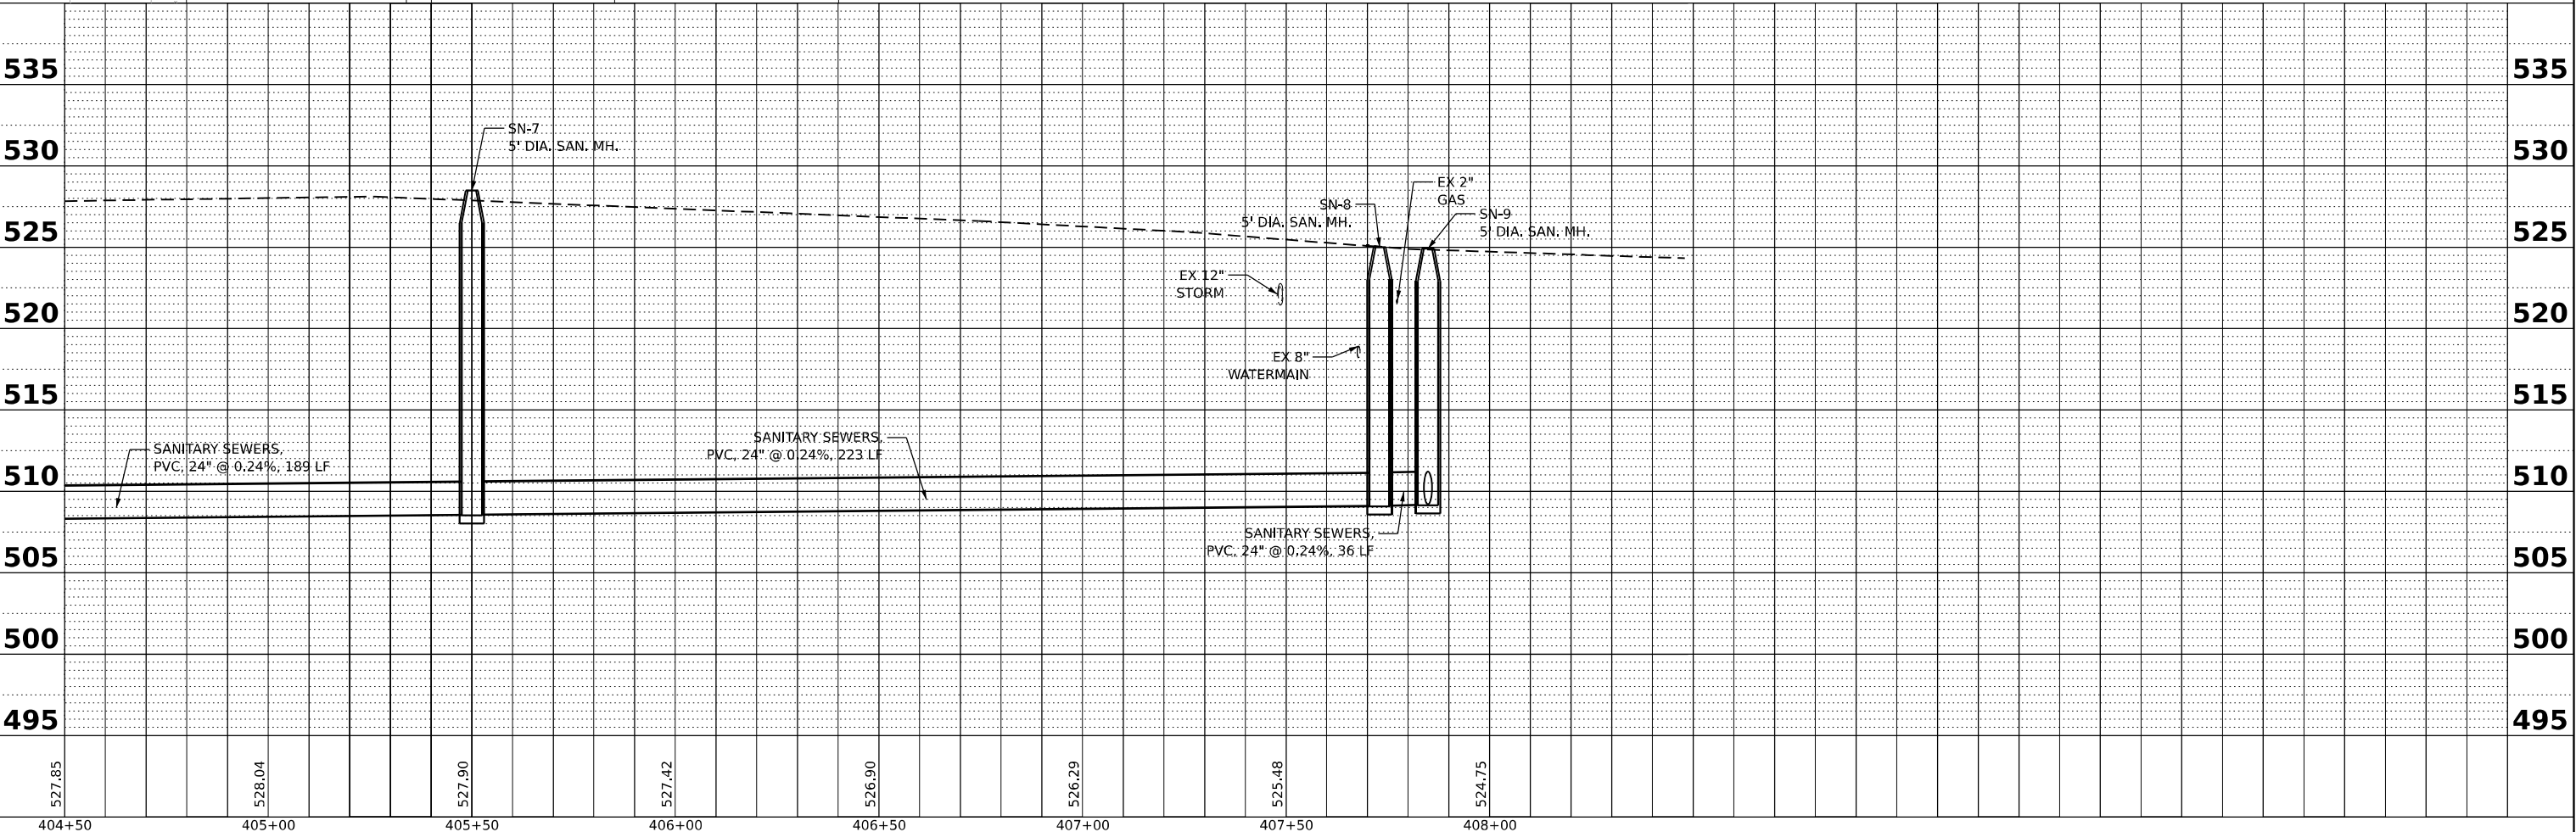

USER NAME = dpung	DESIGNED - CD	REVISED -
PLOT SCALE =	DRAWN - DP	REVISED -
PLOT DATE = 11/5/2025	CHECKED - JH	REVISED -
	DATE - 11/7/2025	REVISED -

STATE OF ILLINOIS
DEPARTMENT OF TRANSPORTATION

JOLIET DRAINAGE AND UTILITY PLAN & PROFILE



SCALE: 1"=20' SHEET 7 OF 13 SHEETS STA. 404+50.00 TO STA. 408+00.00

F.A.I. RTE.	SECTION	COUNTY	TOTAL SHEETS	SHEET NO.
80	FAI 80 21 STRUCTURE 2	WILL	1230	374
CONTRACT NO. 62R23				
ILLINOIS FED. AID PROJECT				


PLAN	SURVEYED PLOTTED ALIGNMENT CHECKED AS SHOWN CADD FILE NAME	BY	DATE
NOTE BOOK NO.			

PROFILE	SURVEYED PLOTTED GRADES CHECKED STRUCTURE NOTATIONS C/F/K/D	BY	DATE
NOTE BOOK NO.			


MODEL Default
FILE NAME: p:\v3\transystems-pub\jenkey.com\transyscorp-pw1\shared\Documents\Projects_2018\CH401\401180022\03-VS97\project_Info\Utilities\CO-V3-V3-Utilities\62R23-4B-1\Sheets\01 62R23-sh-draing.dgn

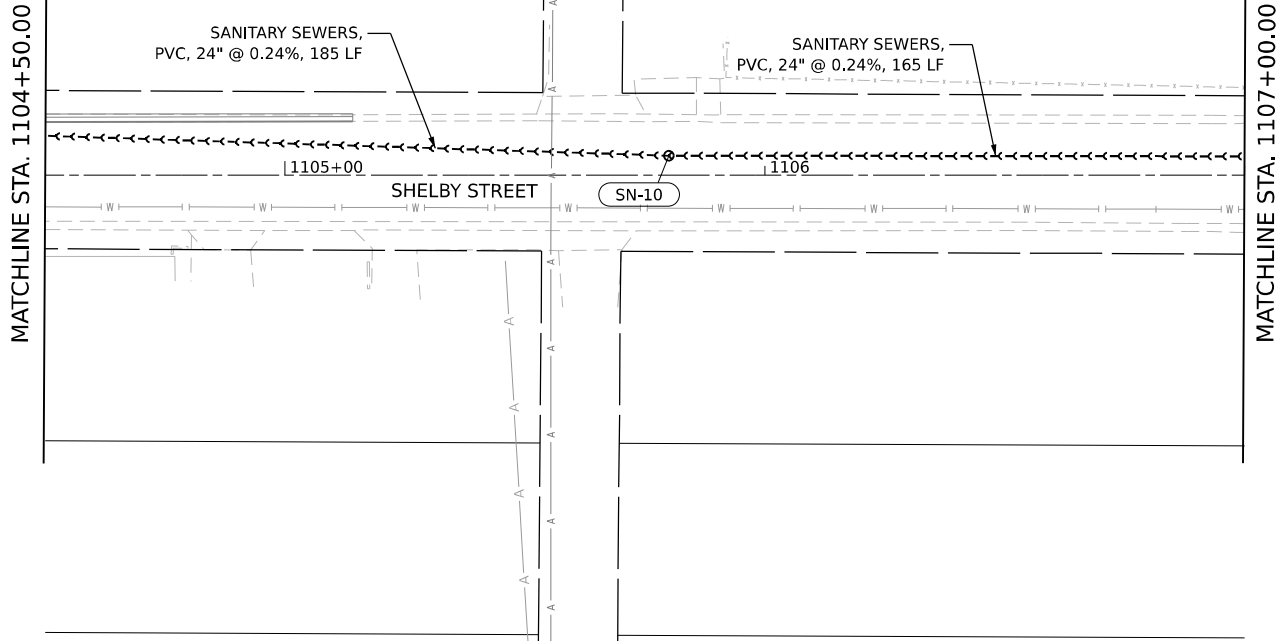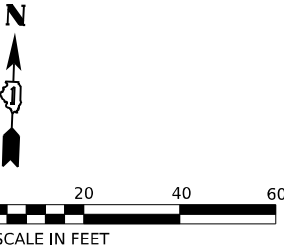

KEY PLAN

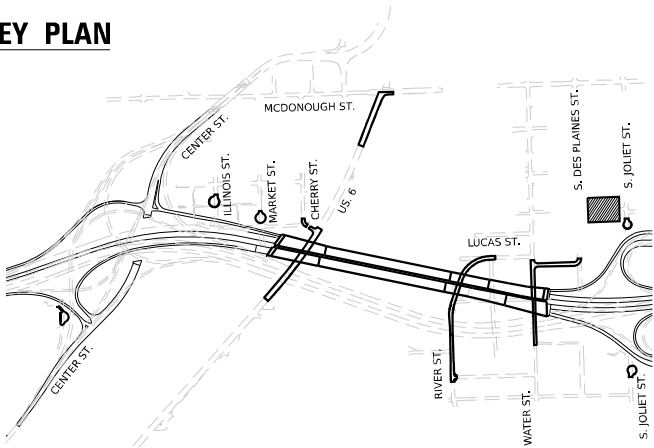

- NOTES:
1. RESIDENTIAL WATER AND SANITARY SERVICES SHOWN ON THIS PLAN ARE THE APPROXIMATE LOCATION OF THE SERVICE. THE CONTRACTOR IS TO FIELD VERIFY AND LOCATE THE SERVICES IF IN CONFLICT.
 2. ALL EXISTING STORM SEWER CONNECTIONS TO PROPOSED DRAINAGE STRUCTURES OR PIPES ARE INCLUDED IN THE COST OF THE PROPOSED DRAINAGE STRUCTURE INSTALLATION OR PROPOSED PIPE INSTALL.
 3. ALL STORM SEWER ON THE PLANS SHALL BE RUBBER GASKETED, REINFORCED CONCRETE PIPE UNLESS OTHERWISE NOTED. ALL SANITARY SEWER ON THE PLANS SHALL BE PVC ASTM D-2241 UNLESS OTHERWISE NOTED.

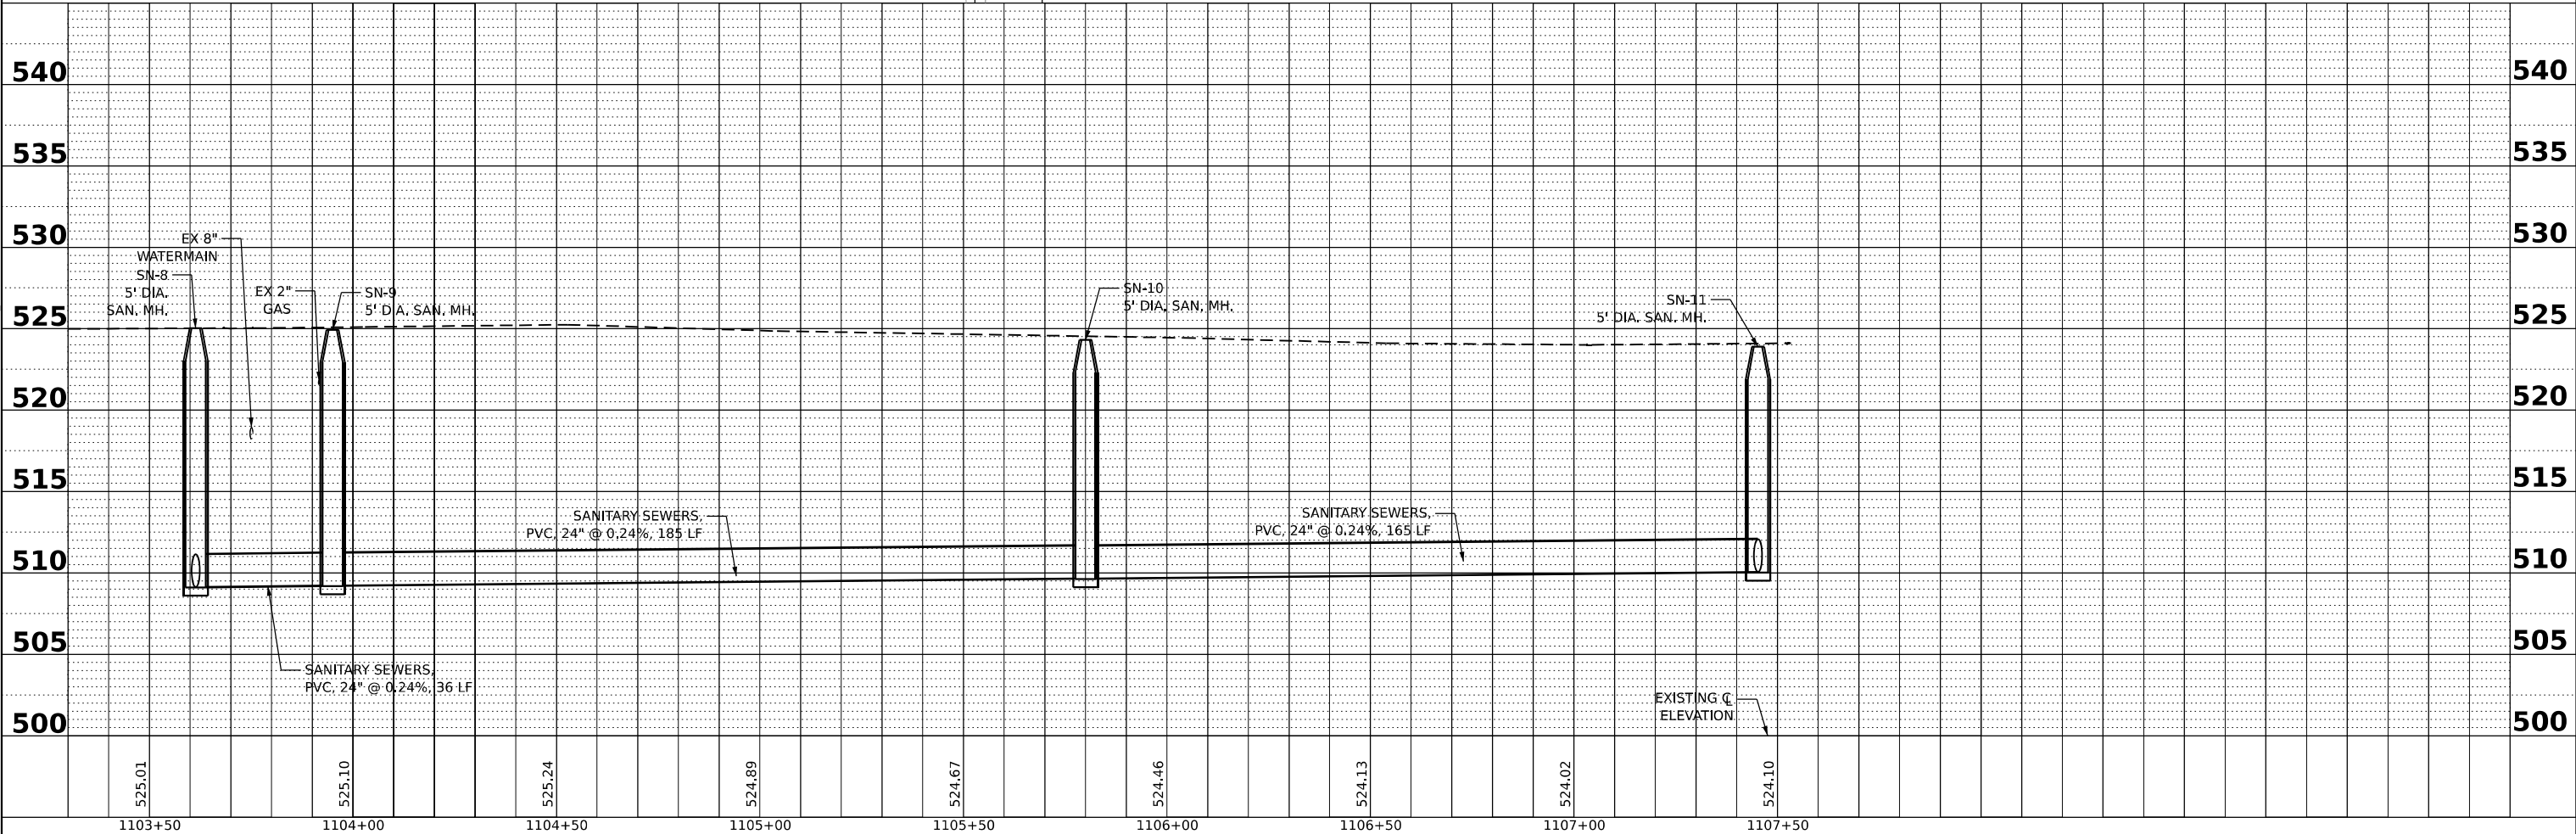

V3
V3 Companies
7325 Janes Avenue
Woodridge, IL 60517
630.724.9200 phone
630.724.9202 fax
www.v3co.com

USER NAME = dpung
PLOT SCALE =
PLOT DATE = 11/5/2025

DESIGNED - CD
DRAWN - DP
CHECKED - JH
DATE - 11/7/2025

REVISED -
REVISED -
REVISED -
REVISED -

STATE OF ILLINOIS
DEPARTMENT OF TRANSPORTATION

JOLIET DRAINAGE AND UTILITY PLAN & PROFILE

SCALE: 1"=20' SHEET 8 OF 13 SHEETS STA. 1104+50.00 TO STA. 1107+00.00

F.A.I. RTE.	SECTION	COUNTY	TOTAL SHEETS	SHEET NO.
80	FAI 80 21 STRUCTURE 2	WILL	1230	375
CONTRACT NO. 62R23				
ILLINOIS		FED. AID PROJECT		

PLAN	SURVEYED	BY	DATE
	PLOTTED		
NOTE BOOK NO.	ALIGNMENT CHECKED		
	STRUCTURE NOTED		




PROFILE	SURVEYED	BY	DATE
	PLOTTED		
NOTE BOOK NO.	GRADES CHECKED		
	STRUCTURE NOTED		

MODEL: Default
FILE NAME: p:\v3\transystems-pw\benley.com\transyscorp-pw\1\shared\Documents\Projects_2018\CH401\401180022\03-VS97\project_Info\Utilities\CO-V3-Utilities\62R23-4B-1\Sheets\0162R23-sh-train03.dgn

- NOTES:
1. RESIDENTIAL WATER AND SANITARY SERVICES SHOWN ON THIS PLAN ARE THE APPROXIMATE LOCATION OF THE SERVICE. THE CONTRACTOR IS TO FIELD VERIFY AND LOCATE THE SERVICES IF IN CONFLICT.
 2. ALL EXISTING STORM SEWER CONNECTIONS TO PROPOSED DRAINAGE STRUCTURES OR PIPES ARE INCLUDED IN THE COST OF THE PROPOSED DRAINAGE STRUCTURE INSTALLATION OR PROPOSED PIPE INSTALL.
 3. ALL STORM SEWER ON THE PLANS SHALL BE RUBBER GASKETED, REINFORCED CONCRETE PIPE UNLESS OTHERWISE NOTED. ALL SANITARY SEWER ON THE PLANS SHALL BE PVC ASTM D-2241 UNLESS OTHERWISE NOTED.

MATCHLINE STA. 1107+00.00

 KEY PLAN

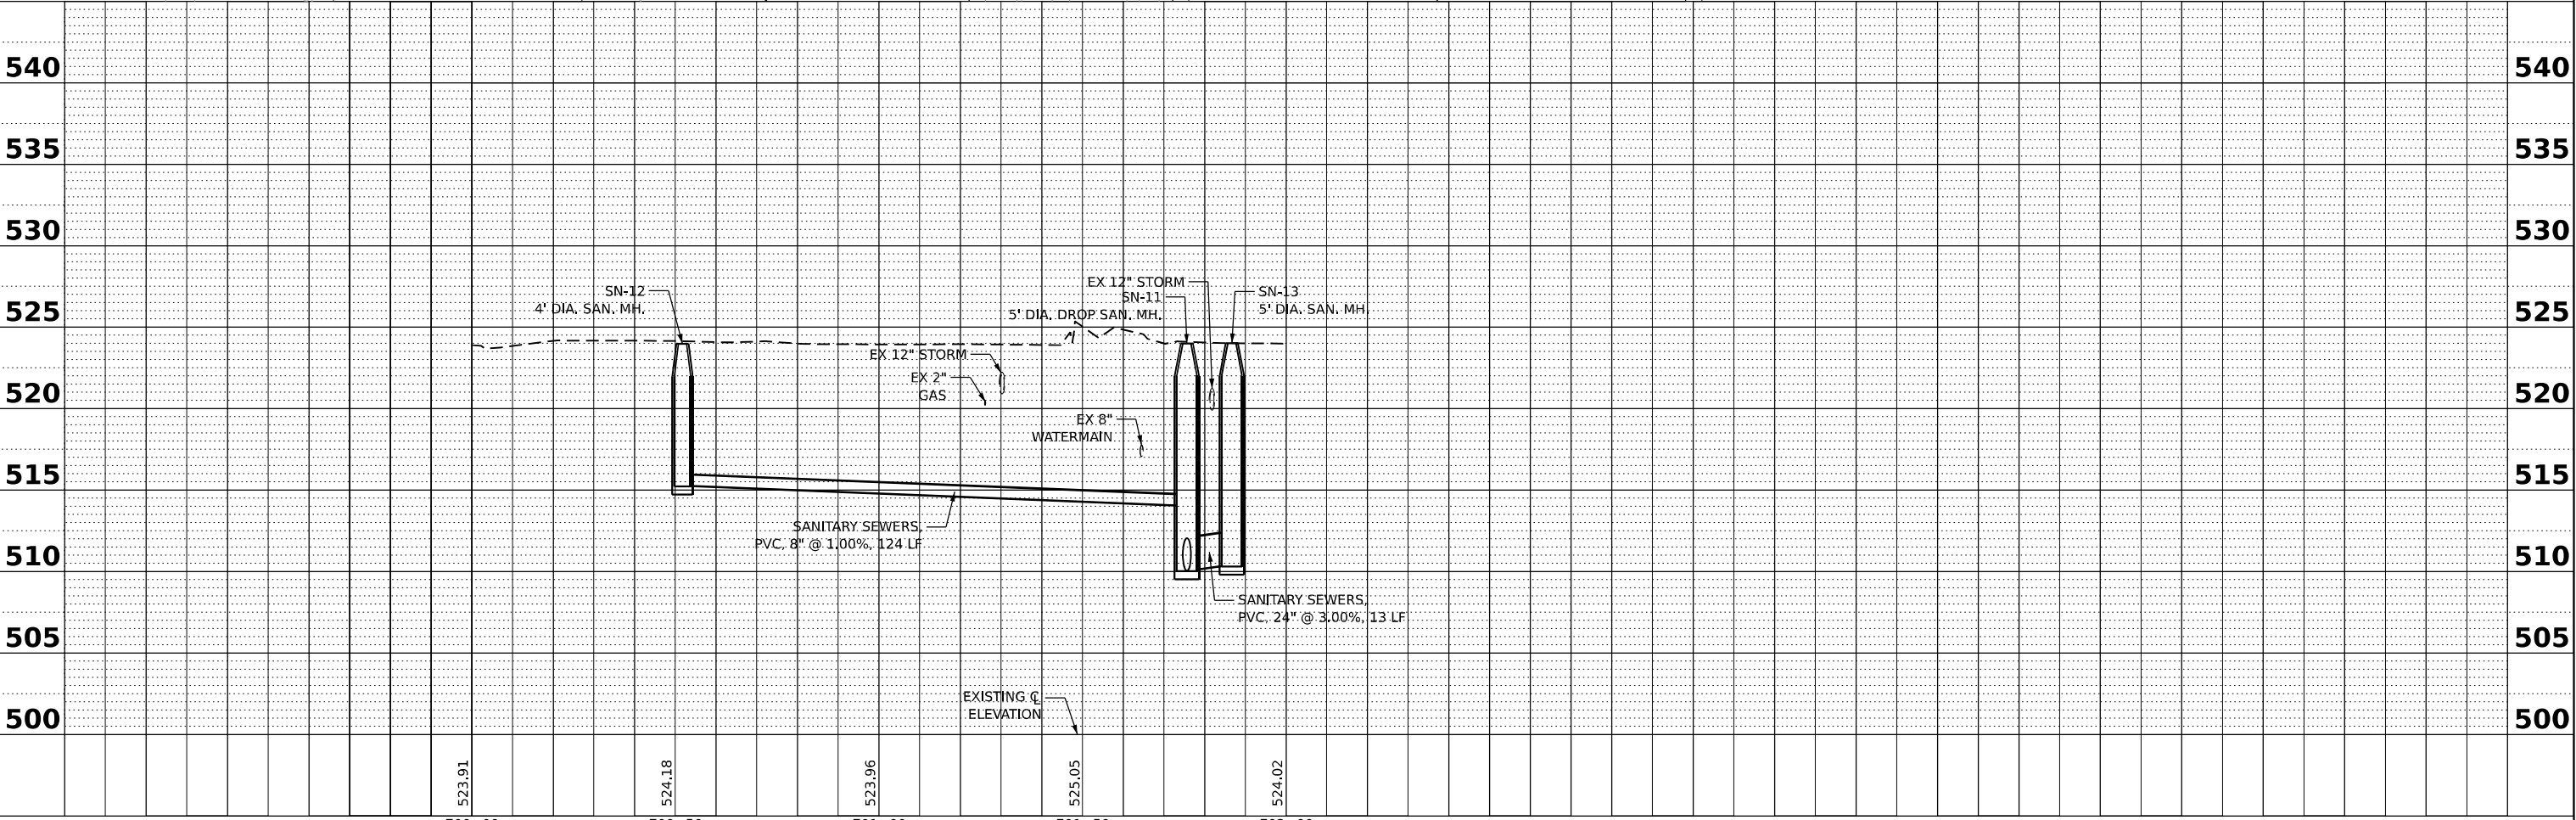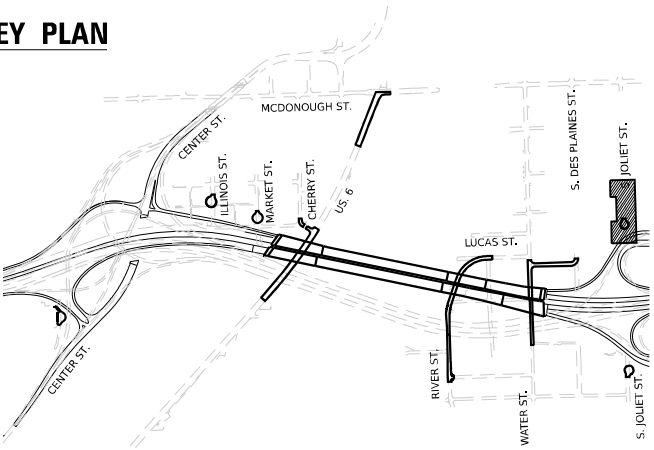

V3 Companies
7325 Janes Avenue
Woodridge, IL 60517
630.724.9200 phone
630.724.9202 fax
www.v3co.com

USER NAME	= dpung
PLOT SCALE	=
PLOT DATE	= 11/5/2025

DESIGNED	- CD
DRAWN	- DP
CHECKED	- JH
DATE	- 11/7/2025

REVISED	-
REVISED	-
REVISED	-
REVISED	-

STATE OF ILLINOIS
DEPARTMENT OF TRANSPORTATION


JOLIET DRAINAGE AND UTILITY PLAN & PROFILE

SCALE: 1"=20' SHEET 9 OF 13 SHEETS STA. 700+00.00 TO STA. 702+00.00


F.A.I. RTE.	SECTION	COUNTY	TOTAL SHEETS	SHEET NO.
80	FAI 80 21 STRUCTURE 2	WILL	1230	376
CONTRACT NO. 62R23				
ILLINOIS		FED. AID PROJECT		

PLAN	SURVEYED PLOTTED ALIGNMENT CHECKED AS BUILT CADD FILE NAME	BY	DATE
NOTE BOOK NO.			

 
- NOTES:
1. RESIDENTIAL WATER AND SANITARY SERVICES SHOWN ON THIS PLAN ARE THE APPROXIMATE LOCATION OF THE SERVICE. THE CONTRACTOR IS TO FIELD VERIFY AND LOCATE THE SERVICES IF IN CONFLICT.
 2. ALL EXISTING STORM SEWER CONNECTIONS TO PROPOSED DRAINAGE STRUCTURES OR PIPES ARE INCLUDED IN THE COST OF THE PROPOSED DRAINAGE STRUCTURE INSTALLATION OR PROPOSED PIPE INSTALL.
 3. ALL STORM SEWER ON THE PLANS SHALL BE RUBBER GASKETED, REINFORCED CONCRETE PIPE UNLESS OTHERWISE NOTED. ALL SANITARY SEWER ON THE PLANS SHALL BE PVC ASTM D-2241 UNLESS OTHERWISE NOTED.



PROFILE	SURVEYED PLOTTED GRADES CHECKED STRUCTURE NOTATIONS CHKD	BY	DATE
NOTE BOOK NO.			

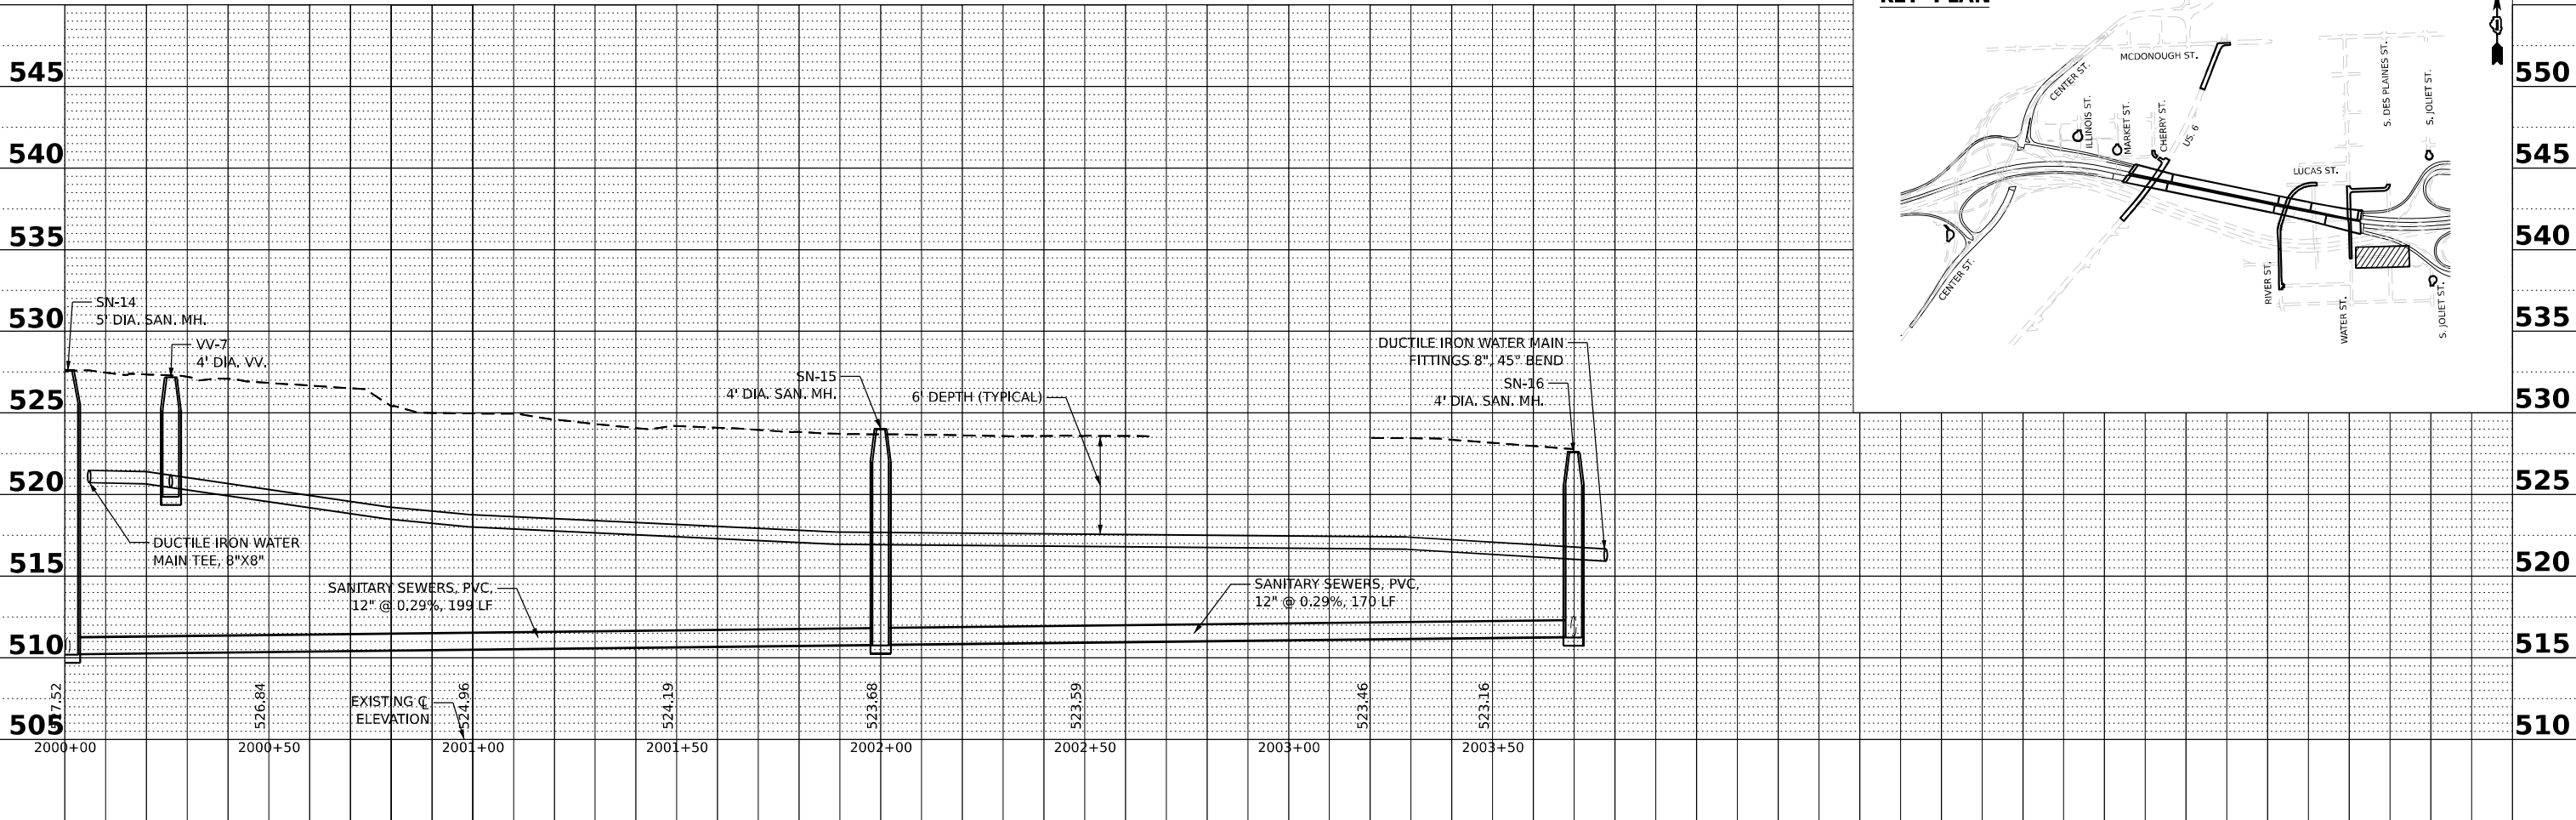

KEY PLAN

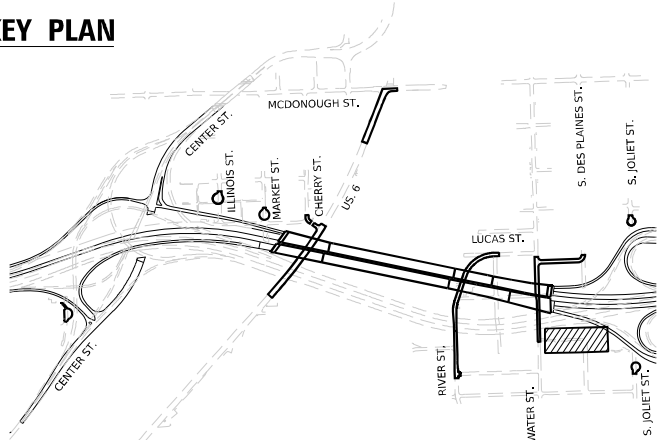

MODEL: Default
FILE NAME: p:\v3\transystems\pub\jenley.com\transys\corp-pw\1\shared\Documents\Projects\2018\CH401\401180022\03-WSP\project_Info\Utilities\CO-V3-Utilities\62R23-4B-1\Sheets\0162R23-sh-train10.dgn



V3 Companies
7325 Janes Avenue
Woodridge, IL 60517
630.724.9200 phone
630.724.9202 fax
www.v3co.com

USER NAME = dpung	DESIGNED - CD	REVISED -
	DRAWN - DP	REVISED -
PLOT SCALE =	CHECKED - JH	REVISED -
PLOT DATE = 11/5/2025	DATE - 11/7/2025	REVISED -

STATE OF ILLINOIS
DEPARTMENT OF TRANSPORTATION

JOLIET DRAINAGE AND UTILITY PLAN & PROFILE


SCALE: 1"=20' SHEET 10 OF 13 SHEETS STA. 2000+50.00 TO STA. 2003+70.00

F.A.I. RTE.	SECTION	COUNTY	TOTAL SHEETS	SHEET NO.
80	FAI 80 21 STRUCTURE 2	WILL	1230	377
CONTRACT NO. 62R23				
ILLINOIS FED. AID PROJECT				

PLAN	SURVEYED	BY	DATE
NOTE BOOK	PLOTTED		
NO.	ALIGNMENT CHECKED		
	CADD FILE NAME		



PROFILE	SURVEYED	BY	DATE
NOTE BOOK	PLOTTED		
NO.	GRADES CHECKED		
	STRUCTURE NOTATIONS CHKD		

MODEL Default
FILE NAME: p:\v3\transystems-pub\ent\key.com\transys\corp-pw\1-sheet\Documents\Projects_2018\CH4011401180022\03-WSP\Project_Info\Utilities\CO-V3-Utilities\62123-AB-1\Sheets\01-62123-sh-Plan1.dgn

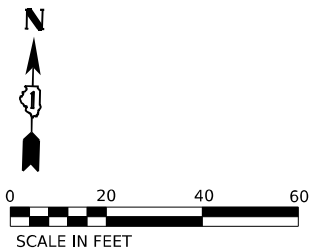


- NOTES:
1. RESIDENTIAL WATER AND SANITARY SERVICES SHOWN ON THIS PLAN ARE THE APPROXIMATE LOCATION OF THE SERVICE. THE CONTRACTOR IS TO FIELD VERIFY AND LOCATE THE SERVICES IF IN CONFLICT.
 2. ALL EXISTING STORM SEWER CONNECTIONS TO PROPOSED DRAINAGE STRUCTURES OR PIPES ARE INCLUDED IN THE COST OF THE PROPOSED DRAINAGE STRUCTURE INSTALLATION OR PROPOSED PIPE INSTALL.
 3. ALL STORM SEWER ON THE PLANS SHALL BE RUBBER GASKETED, REINFORCED CONCRETE PIPE UNLESS OTHERWISE NOTED. ALL SANITARY SEWER ON THE PLANS SHALL BE PVC ASTM D-2241 UNLESS OTHERWISE NOTED.

KEY PLAN

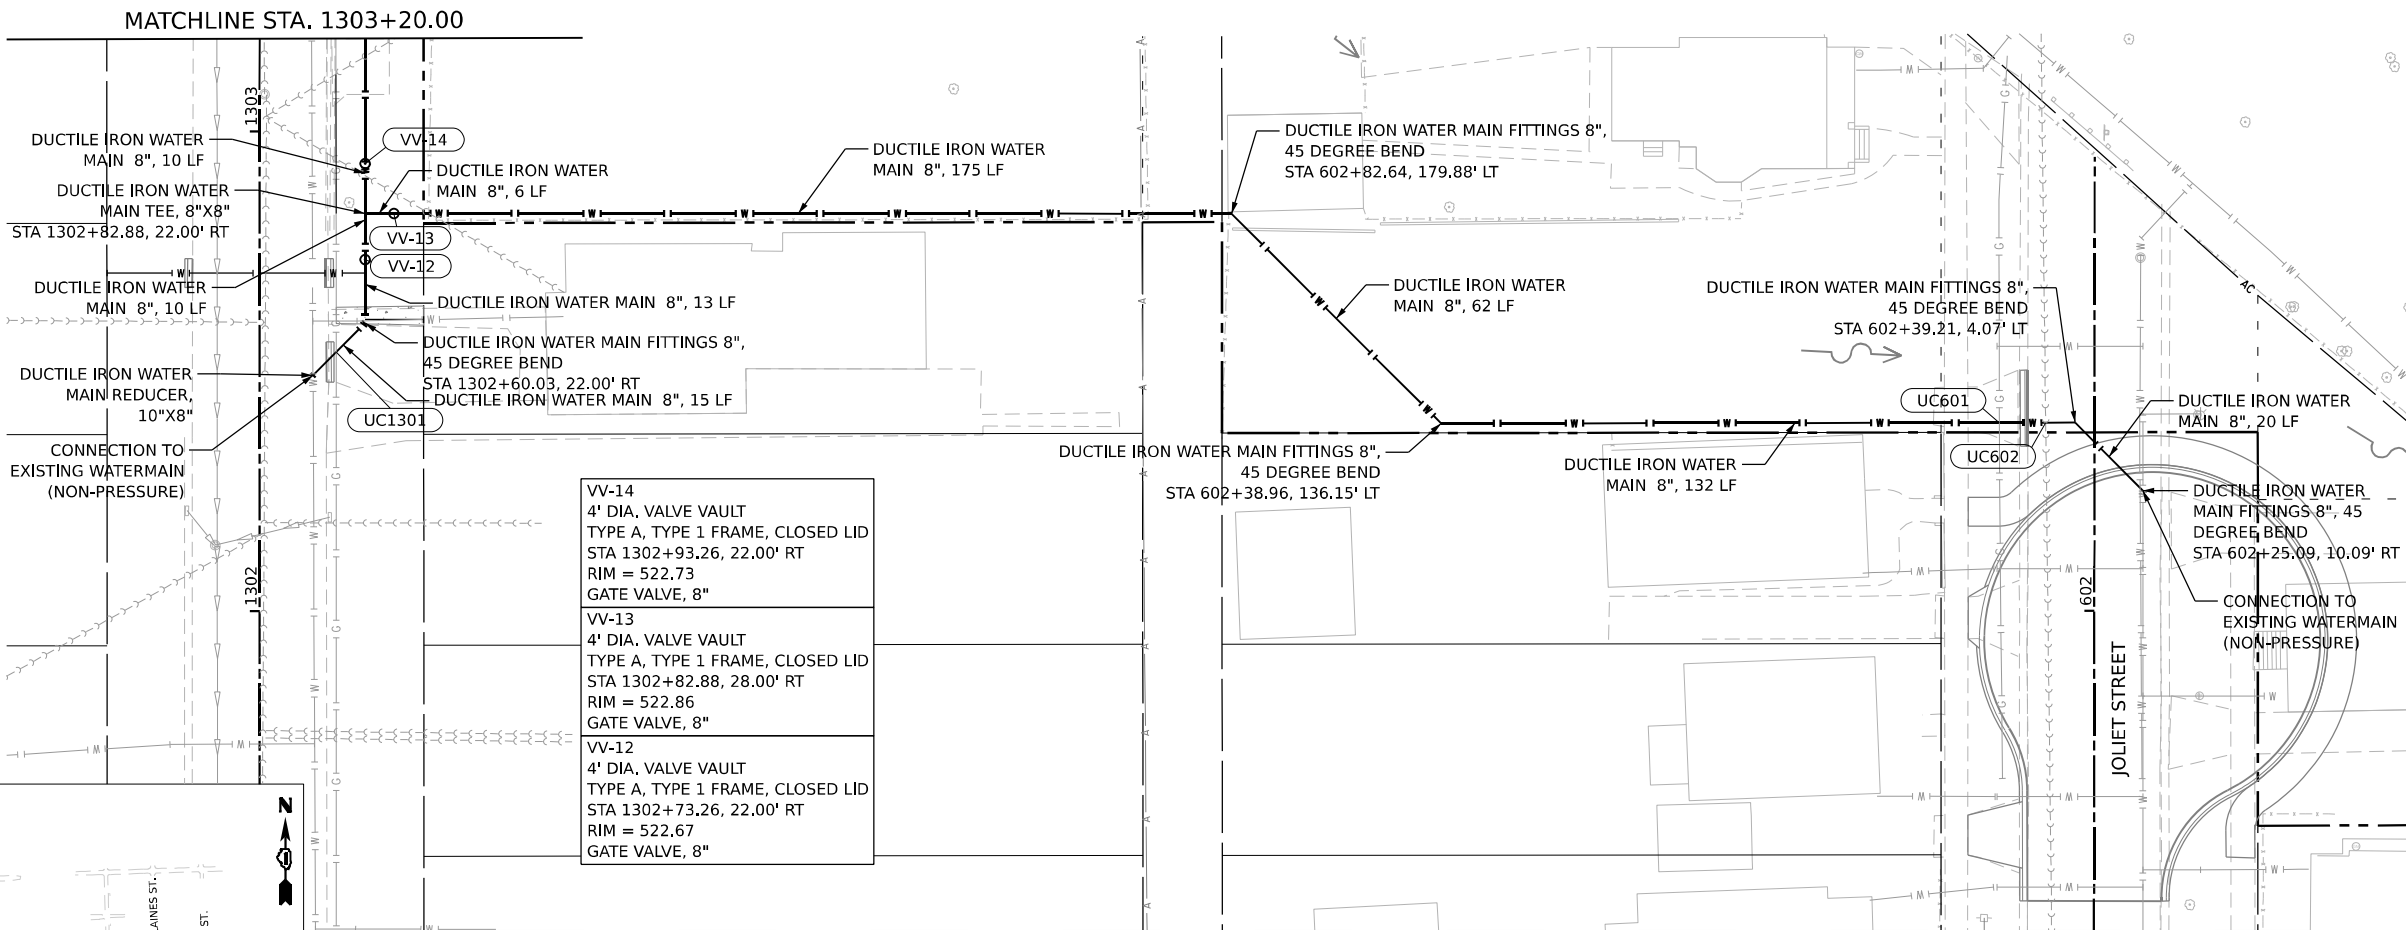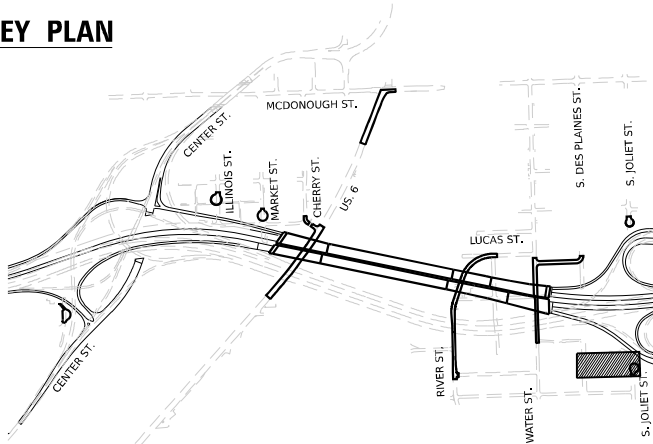

VV-14 4' DIA. VALVE VAULT TYPE A, TYPE 1 FRAME, CLOSED LID STA 1302+93.26, 22.00' RT RIM = 522.73 GATE VALVE, 8"
VV-13 4' DIA. VALVE VAULT TYPE A, TYPE 1 FRAME, CLOSED LID STA 1302+82.88, 28.00' RT RIM = 522.86 GATE VALVE, 8"
VV-12 4' DIA. VALVE VAULT TYPE A, TYPE 1 FRAME, CLOSED LID STA 1302+73.26, 22.00' RT RIM = 522.67 GATE VALVE, 8"

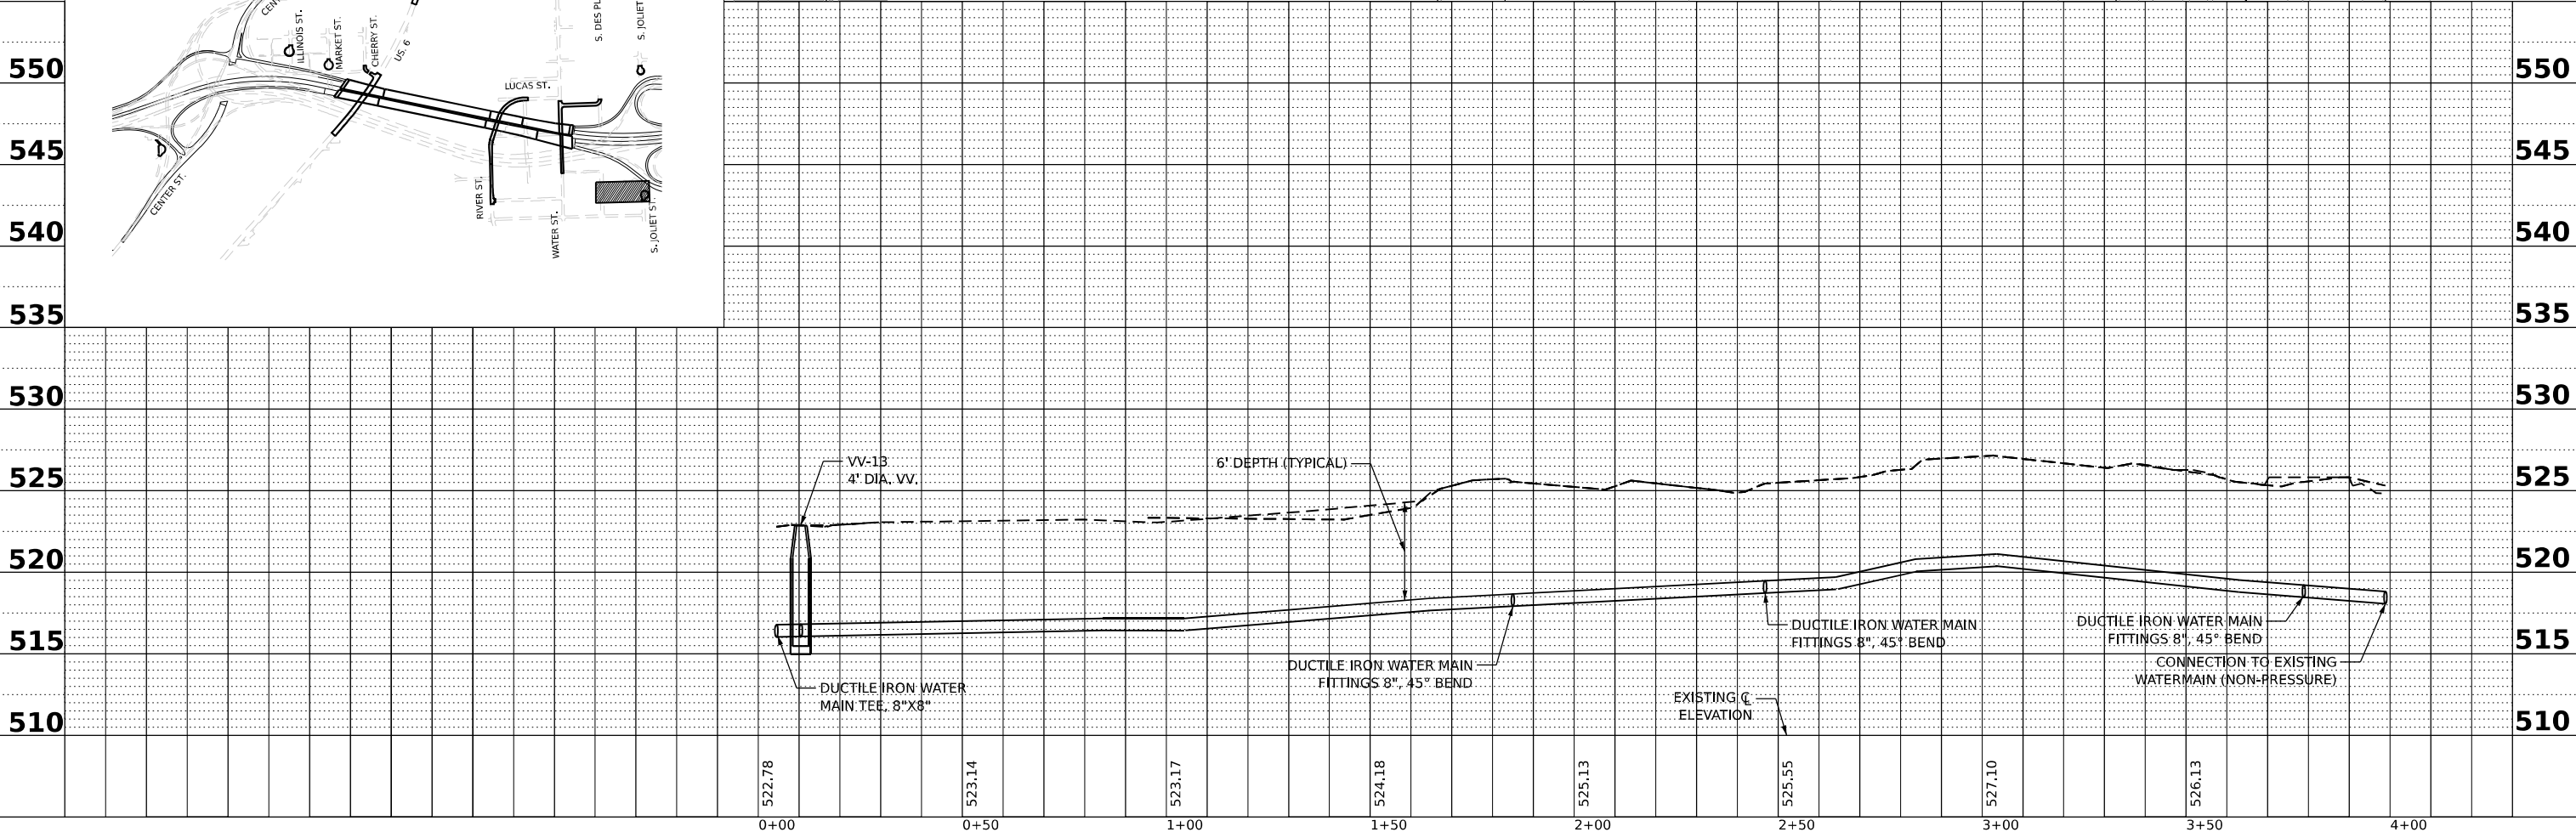

V3 Companies
7325 Janes Avenue
Woodridge, IL 60517
630.724.9200 phone
630.724.9202 fax
www.v3co.com

USER NAME	= dpung	DESIGNED -	CD	REVISED -	
		DRAWN -	DP	REVISED -	
PLOT SCALE	=	CHECKED -	JH	REVISED -	
PLOT DATE	= 11/5/2025	DATE	= 11/7/2025	REVISED -	

STATE OF ILLINOIS
DEPARTMENT OF TRANSPORTATION

JOLIET DRAINAGE AND UTILITY PLAN & PROFILE



SCALE: 1"=20' SHEET 11 OF 13 SHEETS STA. TO STA.

F.A.I. RTE.	SECTION	COUNTY	TOTAL SHEETS	SHEET NO.
80	FAI 80 21 STRUCTURE 2	WILL	1230	378
CONTRACT NO. 62R23				
ILLINOIS FED. AID PROJECT				


PLAN	SURVEYED PLOTTED ALIGNMENT CHECKED AS BUILT CADD FILE NAME	BY	DATE

PROFILE	SURVEYED PLOTTED GRADES CHECKED STRUCTURE NOTATIONS C/F/K/D	BY	DATE

MODEL Default
FILE NAME: p:\v3\transystems\pub\entKey.com\transys\corp-pw\1\shaded\Documents\Projects\2018\CH401\401180022\03-VS7\Project_Info\Utilities\CO-V3-Utilities\62R23-4B-1\Sheets\62R23-sh-train12.dgn

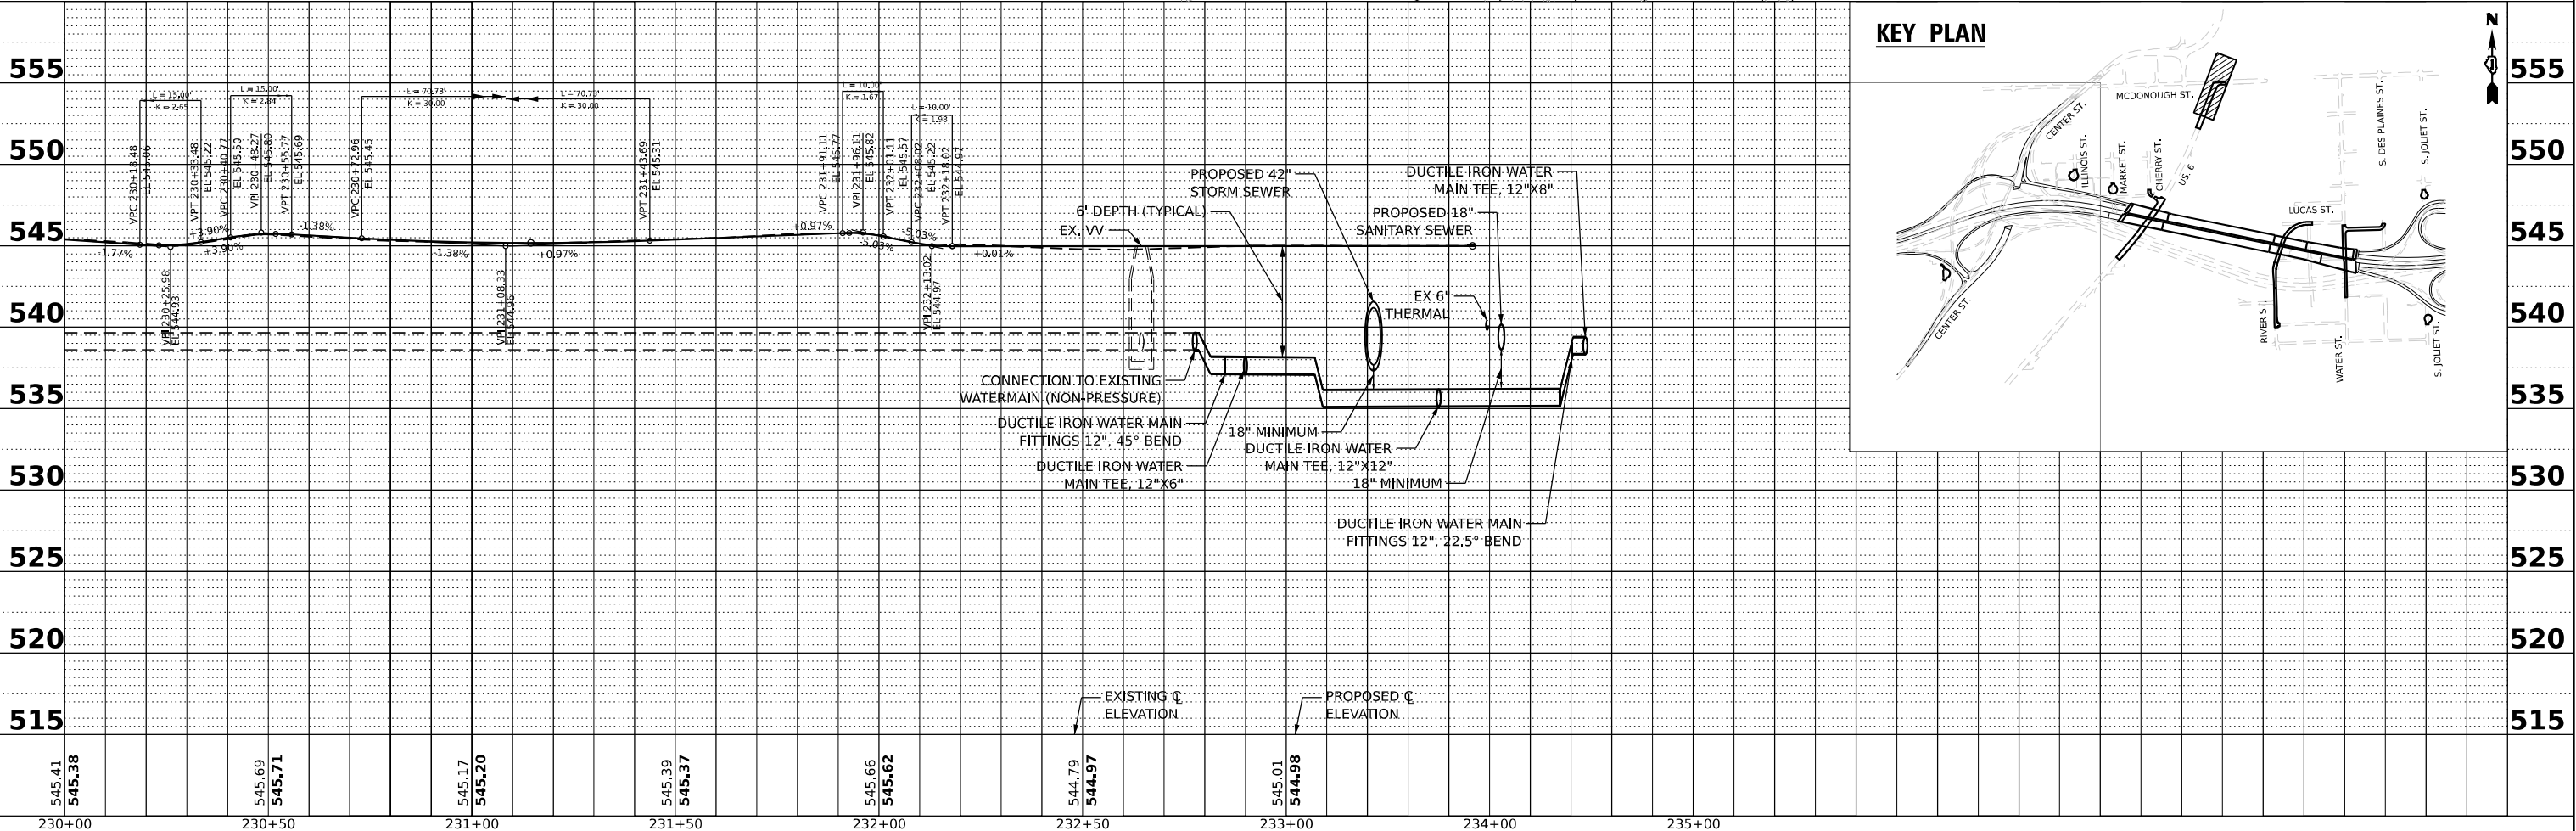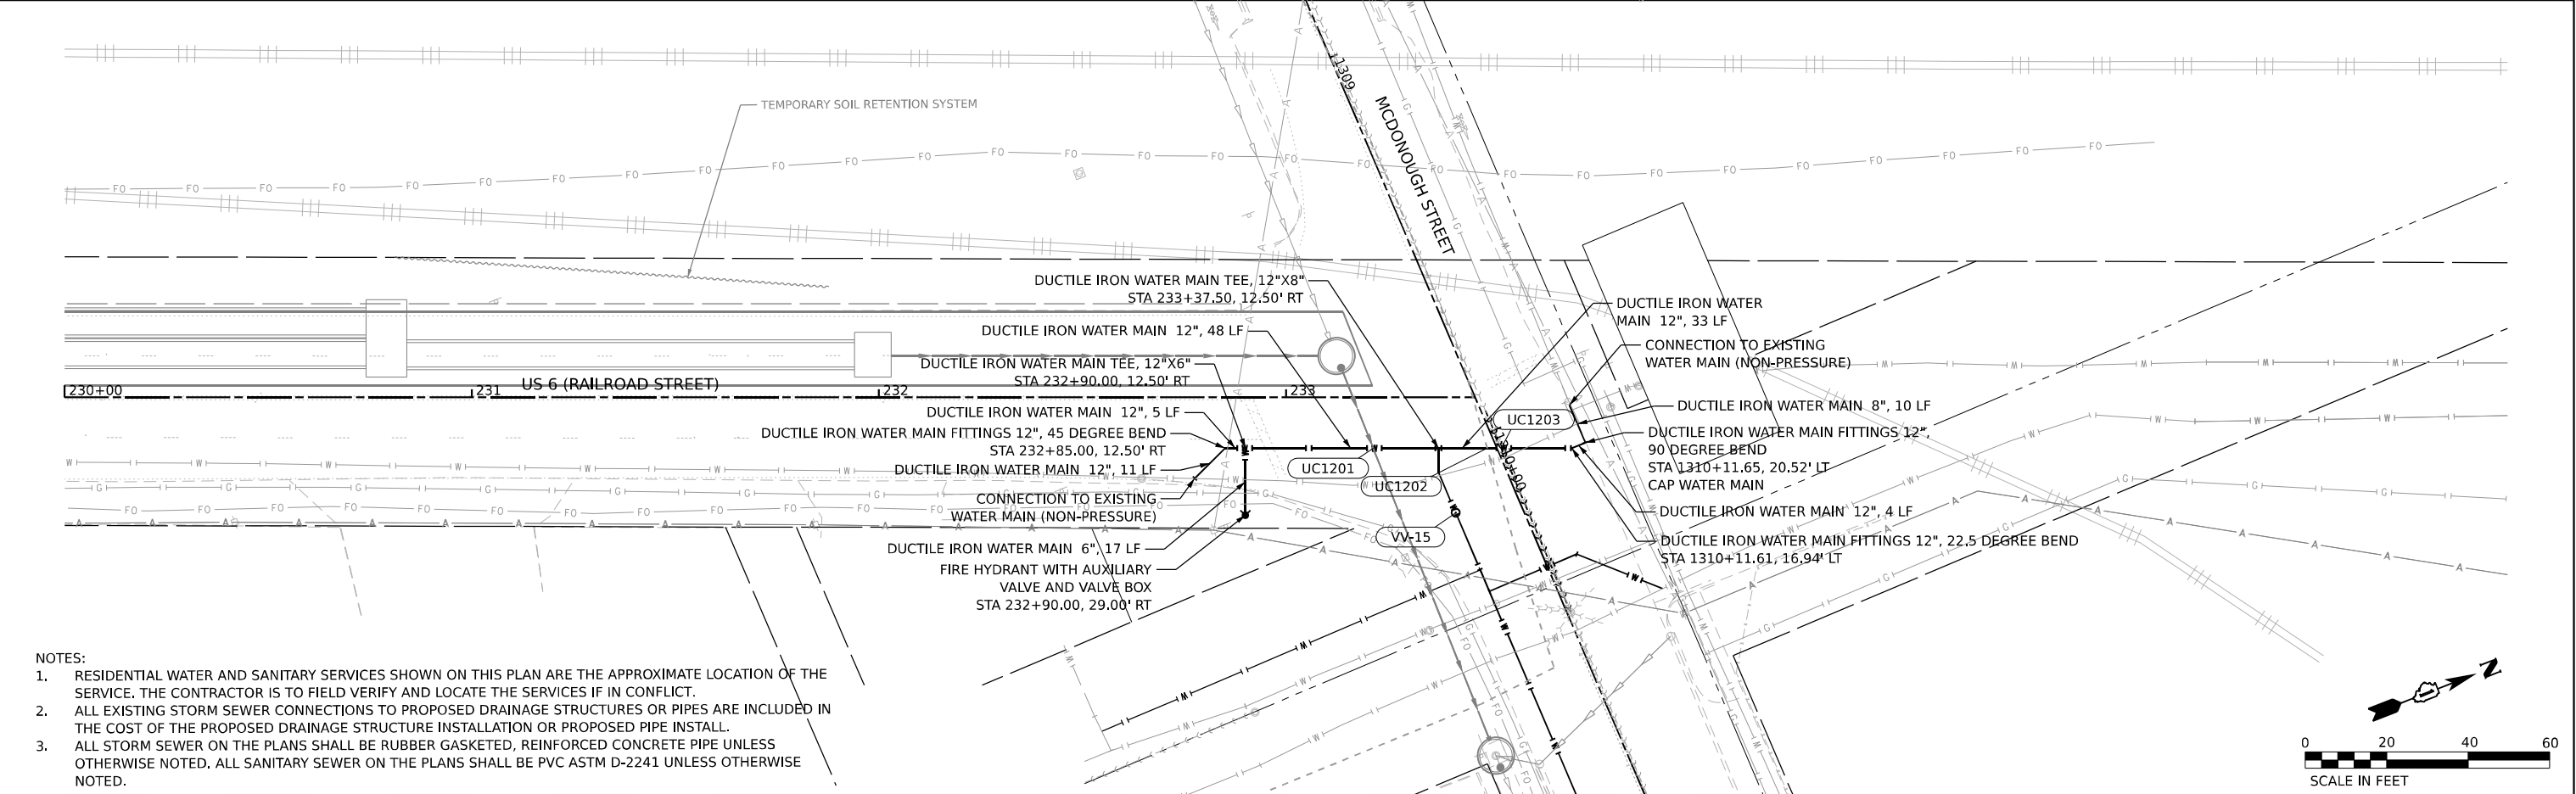

KEY PLAN

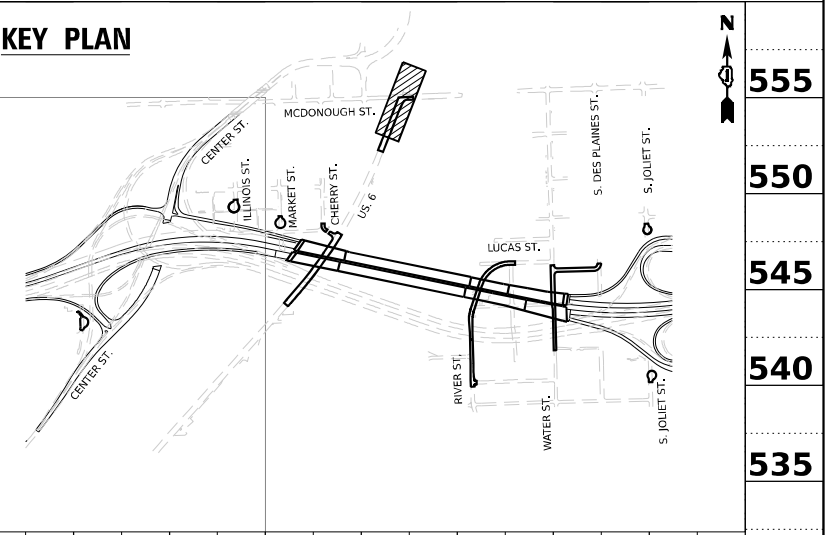

USER NAME = dpung	DESIGNED - CD	REVISED -
PLOT SCALE =	DRAWN - DP	REVISED -
PLOT DATE = 11/5/2025	CHECKED - JH	REVISED -
	DATE - 11/7/2025	REVISED -

STATE OF ILLINOIS
DEPARTMENT OF TRANSPORTATION

JOLIET DRAINAGE AND UTILITY PLAN & PROFILE

SCALE: 1"=20' SHEET 12 OF 13 SHEETS STA. 100+00.00 TO STA. 105+00.00

F.A.I. RTE.	SECTION	COUNTY	TOTAL SHEETS	SHEET NO.
80	FAI 80 21 STRUCTURE 2	WILL	1230	379
CONTRACT NO. 62R23				
ILLINOIS FED. AID PROJECT				

Model: Default
File Name: p:\projects\trans\scorp\ppl-hosted\Documents\projects_2018\CH401\401180022\03-WSP\project_info\utilities\COL-V3-JULIIE62R23-4B-1\Sheets\0162R23-sh-LUCtable1.dgn

LUCAS AVENUE UTILITY CROSSING TABLE								
CROSSING NUMBER	LOCATION		PIPE INFORMATION			INVERT ELEVATION	OUTER ELEVATION	CLEARANCE (FEET)
	STATION	OFFSET	STATUS	SIZE	TYPE			
UC101	100+93.04	8.88' LT	EXISTING	15" RCP	STORM	514.81	514.62 BP	1.86
			PROPOSED	8" DIP	WATER	512.05	512.76 TP	
UC102	100+93.06	1.24' RT	EXISTING	8" PVC	SANITARY	514.30	514.26 BP	1.50
			PROPOSED	8" DIP	WATER	512.05	512.76 TP	
UC103	100+88.95	24.69' RT	EXISTING	12" RCP	STORM	515.55	515.38 BP	1.95
			PROPOSED	8" DIP	WATER	512.72	513.43 TP	
UC104	104+79.61	24.19' LT	PROPOSED	15" RCP	STORM	515.83	515.64 BP	1.90
			PROPOSED	8" DIP	WATER	513.03	513.74 TP	
UC105	111+82.00	9.80' RT	PROPOSED	12" RCP	STORM	516.72	516.55 BP	9.43
			EXISTING	48" RCP	SANITARY	502.70	507.12 TP	
UC106	113+59.01	10.80' RT	PROPOSED	12" RCP	STORM	513.60	513.43 BP	6.06
			EXISTING	48" RCP	SANITARY	502.95	507.37 TP	
UC107	113+59.00	21.00' RT	PROPOSED	12" RCP	STORM	513.66	513.49 BP	1.50
			PROPOSED	8" DIP	WATER	511.28	511.99 TP	
LEGEND: TP = TOP OF PIPE, BP = BOTTOM OF PIPE, DIP = DUCTILE IRON PIPE, RCP = REINFORCED CONCRETE PIPE, PVC = POLYVINYL CHLORIDE, VCP = VITRIFIED CLAY PIPE								

DES PLAINES STREET (NORTH) UTILITY CROSSING TABLE								
CROSSING NUMBER	LOCATION		PIPE INFORMATION			INVERT ELEVATION	OUTER ELEVATION	CLEARANCE (FEET)
	STATION	OFFSET	STATUS	SIZE	TYPE			
UC401	400+69.72	8.00' LI	PROPOSED	12" RCP	STORM	517.38	517.21 BP	7.72
			PROPOSED	24" PVC	SANITARY	507.45	509.49 TP	
UC402	400+69.71	5.00' RT	PROPOSED	12" RCP	STORM	517.26	517.09 BP	1.92
			PROPOSED	8" DIP	WATER	514.46	515.17 TP	
UC403	402+50.04	8.00' LT	PROPOSED	12" RCP	STORM	518.22	518.05 BP	8.13
			PROPOSED	24" PVC	SANITARY	507.88	509.92 TP	
UC404	402+50.02	5.00' RT	PROPOSED	12" RCP	STORM	518.08	517.91 BP	1.50
			PROPOSED	8" DIP	WATER	515.70	516.41 TP	
UC405	407+48.60	10.00' LT	EXISTING	12" RCP	STORM	521.62	521.45 DP	10.33
			PROPOSED	24" PVC	SANITARY	509.08	511.12 TP	
UC406	407+66.30	10.00' LT	EXISTING	4"	ELECTRIC	522.16	522.12 BP	10.96
			PROPOSED	24" PVC	SANITARY	509.12	511.16 TP	
UC407	407+77.85	3.72' RT	EXISTING	8" DIP	WATER	518.75	518.71 BP	7.49
			PROPOSED	24" PVC	SANITARY	509.18	511.22 TP	
UC408	407+79.08	20.61' LT	EXISTING	12" RCP	STORM	521.30	521.13 BP	9.17
			PROPOSED	18" PVC	SANITARY	510.46	511.96 TP	
UC409	407+82.82	17.77' RT	EXISTING	4"	ELECTRIC	522.08	522.04 BP	10.78
			PROPOSED	24" PVC	SANITARY	509.22	511.26 TP	
LEGEND: TP = TOP OF PIPE, BP = BOTTOM OF PIPE, DIP = DUCTILE IRON PIPE RCP = REINFORCED CONCRETE PIPE, PVC = POLYVINYL CHLORIDE, VCP = VITRIFIED CLAY PIPE								

JOLIET STREET (NORTH) UTILITY CROSSING TABLE								
CROSSING NUMBER	LOCATION		PIPE INFORMATION			INVERT ELEVATION	OUTER ELEVATION	CLEARANCE (FEET)
	STATION	OFFSET	STATUS	SIZE	TYPE			
UC701	700+61.00	21.58' LT	EXISTING	2" STL	GAS	521.03	520.99 BP	2.76
			PROPOSED	6" DIP	WATER	517.69	518.23 TP	
UC702	700+61.00	8.25' LT	PROPOSED	6" DIP	WATER	517.70	517.66 BP	1.73
			PROPOSED	8" PVC	SANITARY	515.22	515.93 TP	
UC703	701+26.10	8.18' LT	EXISTING	2" STL	GAS	520.26	520.22 BP	4.94
			PROPOSED	8" PVC	SANITARY	514.57	515.28 TP	
UC704	701+30.24	8.17' LT	EXISTING	12" RCP	STORM	521.10	520.93 BP	5.69
			PROPOSED	8" PVC	SANITARY	514.53	515.24 TP	
UC705	701+64.54	8.13' LT	EXISTING	8" DIP	WATER	517.58	517.54 BP	2.65
			PROPOSED	8" PVC	SANITARY	514.18	514.89 TP	
UC706	701+75.59	21.23' LT	EXISTING	2" STL	GAS	520.21	520.17 BP	8.09
			PROPOSED	24" PVC	SANITARY	510.04	512.08 TP	
UC707	701+81.82	4.53' LT	EXISTING	12" RCP	STORM	520.10	519.93 BP	7.60
			PROPOSED	24" PVC	SANITARY	510.29	512.33 TP	
LEGEND: TP = TOP OF PIPE, BP = BOTTOM OF PIPE, DIP = DUCTILE IRON PIPE, RCP = REINFORCED CONCRETE PIPE, PVC = POLYVINYL CHLORIDE, VCP = VITRIFIED CLAY PIPE								

DES PLAINES STREET (SOUTH) UTILITY CROSSING TABLE								
CROSSING NUMBER	LOCATION		PIPE INFORMATION			INVERT ELEVATION	OUTER ELEVATION	CLEARANCE (FEET)
	STATION	OFFSET	STATUS	SIZE	TYPE			
UC1301	1202+54.68	15.99' RT	EXISTING	2" STL	GAS	519.09	519.05 BP	3.08
			PROPOSED	8" DIP	WATER	515.26	515.97 TP	
LEGEND: TP = TOP OF PIPE, BP = BOTTOM OF PIPE, DIP = DUCTILE IRON PIPE, RCP = REINFORCED CONCRETE PIPE, PVC = POLYVINYL CHLORIDE, VCP = VITRIFIED CLAY PIPE								

JOLIET STREET (SOUTH) UTILITY CROSSING TABLE								
CROSSING NUMBER	LOCATION		PIPE INFORMATION			INVERT ELEVATION	OUTER ELEVATION	CLEARANCE (FEET)
	STATION	OFFSET	STATUS	SIZE	TYPE			
UC601	602+39.18	19.80' LT	EXISTING	2" STL	GAS	522.31	522.27 BP	2.75
			PROPOSED	8" DIP	WATER	518.81	519.52 TP	
UC602	602+39.20	10.17' LT	PROPOSED	8" DIP	WATER	518.62	518.58 BP	6.21
			EXISTING	48" RCP	SANITARY	507.95	512.37 TP	
LEGEND: TP = TOP OF PIPE, BP = BOTTOM OF PIPE, DIP = DUCTILE IRON PIPE, RCP = REINFORCED CONCRETE PIPE, PVC = POLYVINYL CHLORIDE, VCP = VITRIFIED CLAY PIPE								



V3 Companies
7325 Jones Avenue
Woodridge, IL 60517
630.724.9200 phone
630.724.9202 fax
www.v3co.com

USER NAME	=	djpong
PLOT SCALE	=	
PLOT DATE	=	11/5/2025

DESIGNED	-	CD
DRAWN	-	DP
CHECKED	-	JH
DATE	-	11/7/2025

REVISED	-	
REVISED	-	
REVISED	-	
REVISED	-	

STATE OF ILLINOIS
DEPARTMENT OF TRANSPORTATION

JOLIET DRAINAGE AND UTILITY PLAN & PROFILE CONFLICT TABLE			
SCALE: 1"=20'	SHEET 1	OF 2 SHEETS	STA. TO STA.

F.A.I. RTE.	SECTION	COUNTY	TOTAL SHEETS	SHEET NO.
80	FAI 80 21 STRUCTURE 2	WILL	1230	381
CONTRACT NO. 62R23				
		ILLINOIS	FED. AID PROJECT	

LEGEND: TP = TOP OF PIPE, BP = BOTTOM OF PIPE, DIP = DUCTILE IRON PIPE, RCP = REINFORCED CONCRETE PIPE, PVC = POLYVINYL CHLORIDE, VCP = VITRIFIED CLAY PIPE								
WATER STREET UTILITY CROSSING TABLE								
CROSSING NUMBER	LOCATION		PIPE INFORMATION			INVERT ELEVATION	OUTER ELEVATION	CLEARANCE (FEET)
	STATION	OFFSET	STATUS	SIZE	TYPE			
UC301	299+11.54	9.11' RT	EXISTING	12" RCP	STORM	520.48	520.31 BP	2.08
			PROPOSED	8" DIP	WATER	517.52	518.23 TP	
UC302	299+35.00	13.48' RT	EXISTING	2"	ELECTRIC	521.65	521.61 BP	3.03
			PROPOSED	6" DIP	WATER	518.04	518.58 TP	
UC303	299+92.36	6.00' RT	EXISTING	8" VCP	SANITARY	520.25	520.21 BP	0.77
			PROPOSED	8" DIP	WATER	518.73	519.44 TP	
UC304	301+38.01	16.59' RT	EXISTING	2"	ELECTRIC	524.71	524.67 BP	3.24
			PROPOSED	8" DIP	WATER	520.72	521.43 TP	
UC305	301+49.01	6.00' RT	PROPOSED	8" DIP	WATER	520.51	520.47 BP	9.18
			PROPOSED	12" PVC	SANITARY	510.25	511.29 TP	
UC306	301+49.01	16.62' RT	EXISTING	2"	ELECTRIC	524.71	524.67 BP	13.35
			PROPOSED	12" PVC	SANITARY	510.28	511.32 TP	
UC307	301+90.00	1.05' RT	PROPOSED	6" DIP	WATER	519.80	519.76 BP	8.67
			EXISTING	12" VCP	SANITARY	510.05	511.09 TP	
UC308	304+74.94	9.00' RT	PROPOSED	2"	ELECTRIC	519.79	519.75 BP	3.22
			PROPOSED	8" DIP	WATER	515.82	516.53 TP	
UC309	304+37.92	9.00' RT	EXISTING	12" RCP	STORM	519.76	519.59 BP	3.15
			PROPOSED	8" DIP	WATER	515.73	516.44 TP	
UC310	304+58.16	9.00' RT	EXISTING	2" STL	GAS	519.62	519.58 BP	3.29
			PROPOSED	8" DIP	WATER	515.58	516.29 TP	
UC311	304+65.00	6.39' LT	EXISTING	12" RCP	STORM	518.95	518.78 BP	2.54
			PROPOSED	6" DIP	WATER	515.70	516.24 TP	
UC312	304+65.00	2.95' RT	PROPOSED	6" DIP	WATER	515.70	515.66 BP	5.76
			EXISTING	12" VCP	SANITARY	508.86	509.90 TP	
UC313	306+10.67	9.00' RT	EXISTING	12" RCP	STORM	518.29	518.12 BP	2.83
			PROPOSED	8" DIP	WATER	514.58	515.29 TP	
UC314	306+12.14	3.01' RT	EXISTING	12" RCP	STORM	518.06	517.89 BP	10.70
			PROPOSED	12" PVC	SANITARY	506.15	507.19 TP	
UC315	306+98.57	9.00' RT	PROPOSED	15" RCP	STORM	516.10	515.91 BP	1.50
			PROPOSED	8" DIP	WATER	513.70	514.41 TP	
UC316	306+98.820	3.00' RT	PROPOSED	15" RCP	STORM	516.08	515.89 BP	10.39
			PROPOSED	12" PVC	SANITARY	504.46	505.50 TP	
UC317	307+38.74	19.50' RT	EXISTING	2" STL	GAS	517.49	517.45 BP	2.81
			PROPOSED	8" DIP	WATER	513.93	514.64 TP	
UC318	307+51.73	9.05' RT	PROPOSED	8" DIP	WATER	513.86	513.82 BP	4.48
			PROPOSED	24" PVC	SANITARY	507.30	509.34 TP	
UC319	307+51.73	13.11' RT	EXISTING	2" STL	GAS	517.44	517.40 BP	8.03
			PROPOSED	24" PVC	SANITARY	507.33	509.37 TP	
UC320	307+90.54	17.78' LT	PROPOSED	2"	ELECTRIC	517.55	517.10 BP	3.04
			PROPOSED	8" DIP	WATER	513.35	514.06 TP	
UC321	307+90.57	11.15' LT	PROPOSED	18" RCP	STORM	515.61	515.40 BP	1.28
			PROPOSED	8" DIP	WATER	513.41	514.12 TP	
UC322	307+90.60	4.13' LT	PROPOSED	8" DIP	WATER	513.51	513.47 BP	4.23
			PROPOSED	24" PVC	SANITARY	507.20	509.24 TP	
UC323	307+99.50	21.62' LT	PROPOSED	12" RCP	STORM	515.71	515.54 BP	7.99
			EXISTING	48" RCP	SANITARY	503.13	507.55 TP	
UC324	307+99.45	11.83' LT	PROPOSED	18" RCP	STORM	515.57	515.36 BP	7.80
			EXISTING	48" RCP	SANITARY	503.14	507.56 TP	
UC325	308+13.13	17.78' LT	PROPOSED	2"	ELECTRIC	517.63	517.59 BP	0.85
			PROPOSED	12" RCP	STORM	515.57		

US 6 (RAILROAD STREET) UTILITY CROSSING TABLE								
CROSSING NUMBER	LOCATION		PIPE INFORMATION			INVERT ELEVATION	OUTER ELEVATION	CLEARANCE (FEET)
	STATION	OFFSET	STATUS	SIZE	TYPE			
UC1201	233+21.42	12.50' RT	PROPOSED	42" RCP	STORM	537.68	537.31 BP	1.13
			PROPOSED	12" DIP	WATER	535.13	536.18 TP	
UC1202	233+49.39	12.50' RT	EXISTING	2" STL	THERMAL	539.86 (APPROX.)	539.82 BP (APPROX.)	3.61
			PROPOSED	12" DIP	WATER	535.16	536.21 TP	
UC1203	233+52.87	12.50' RT	PROPOSED	18" PVC	SANITARY	538.65	538.61 BP	2.39
			PROPOSED	12" DIP	WATER	535.17	536.22 TP	


LEGEND: TP = TOP OF PIPE, BP = BOTTOM OF PIPE, DIP = DUCTILE IRON PIPE, RCP = REINFORCED CONCRETE PIPE, PVC = POLYVINYL CHLORIDE, VCP = VITRIFIED CLAY PIPE

MCDONOUGH STREET UTILITY CROSSING TABLE								
CROSSING NUMBER	LOCATION		PIPE INFORMATION			INVERT ELEVATION	OUTER ELEVATION	CLEARANCE (FEET)
	STATION	OFFSET	STATUS	SIZE	TYPE			
UC1302	1310+36.00	0.93' LT	PROPOSED	18" PVC	SANITARY	537.33	537.29 BP	0.94
			PROPOSED	12" DIP	WATER	536.00	536.35 TP	
UC1303	1310+36.00	6.08' RT	EXISTING	2" STL	THERMAL	539.22 (APPROX.)	539.18 BP (APPROX.)	2.83
			PROPOSED	12" DIP	WATER	536.00	536.35 TP	
UC1304	1310+59.93	15.50' RT	PROPOSED	2" STL	THERMAL	539.77 (APPROX.)	539.73 BP (APPROX.)	3.27
			PROPOSED	8" DIP	WATER	535.75	536.46 TP	
UC1305	1310+77.86	15.50' RT	PROPOSED	12" RCP	STORM	540.08	539.91 BP	3.76
			PROPOSED	8" DIP	WATER	535.44	536.15 TP	
UC1306	1312+01.88	15.50' RT	PROPOSED	12" RCP	STORM	538.87	538.70 BP	3.01
			PROPOSED	8" DIP	WATER	534.98	535.69 TP	
UC1307	1312+76.05	15.50' RT	PROPOSED	12" RCP	STORM	537.60	537.43 BP	1.56
			PROPOSED	8" DIP	WATER	535.16	535.87 TP	
UC1308	1312+76.74	15.50' RT	PROPOSED	8" VCP	STORM	536.95	536.91 BP	1.04
			PROPOSED	8" DIP	WATER	535.16	535.87 TP	


LEGEND: TP = TOP OF PIPE, BP = BOTTOM OF PIPE, DIP = DUCTILE IRON PIPE, RCP = REINFORCED CONCRETE PIPE, PVC = POLYVINYL CHLORIDE, VCP = VITRIFIED CLAY PIPE

MODEL: Default
FILE NAME: pw:/transystems-cw.bentley.com/transyscorp-pw1-hosted/Documents/Projects_2018/CH401/401180022/03-WSP/Project_Info/Utilities/CO-1/3-Utilities/62R23-RB-1/Sheets/62R23-sht-1/CTable2.dgn

 V3 Companies 7325 James Avenue Woodridge, IL 60517 630.724.9200 phone 630.724.9202 fax www.v3co.com	USER NAME = dpung	DESIGNED - CD	REVISED -	STATE OF ILLINOIS DEPARTMENT OF TRANSPORTATION	JOLIET DRAINAGE AND UTILITY PLAN & PROFILE CONFLICT TABLE				F.A.I. RTE.	SECTION	COUNTY	TOTAL SHEETS	SHEET NO.
	PLOT SCALE =	DRAWN - DP	REVISED -							FAI 80 21 STRUCTURE 2	WILL	1230	382
	PLOT DATE = 11/5/2025	CHECKED - JH	REVISED -		SCALE: 1"=20' SHEET 2 OF 2 SHEETS STA. TO STA.					CONTRACT NO. 62R23			
		DATE - 11/7/2025	REVISED -							ILLINOIS FED. AID PROJECT			

 STATION / OFFSET FOR DRAINAGE STRUCTURES

END SECTION

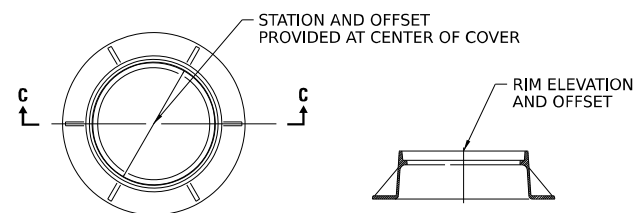


PLAN VIEW

SECTION C-C

TYPE 1 LID


MANHOLE WITH CIRCULAR LIDS

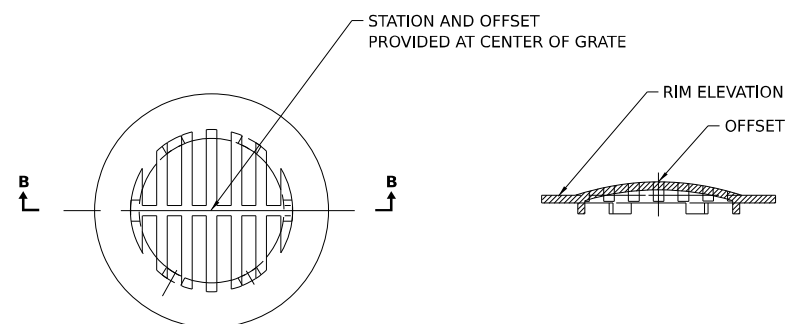


PLAN VIEW

SECTION B-B

TYPE 8 GRATE

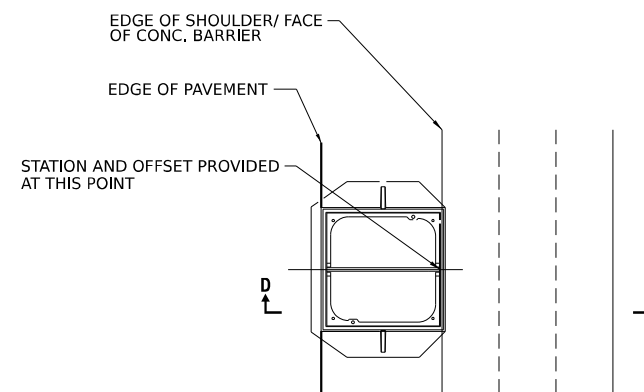


PLAN VIEW

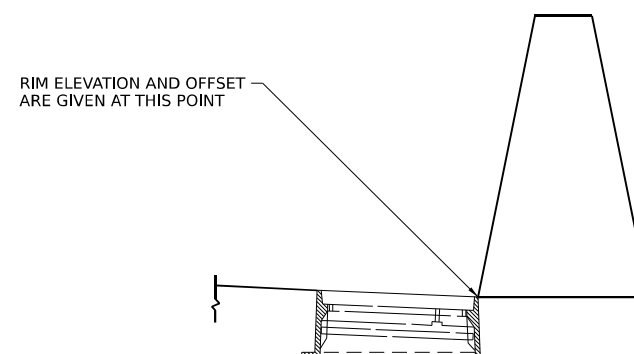


SECTION D-D

TYPE 20 / 22 FRAME & GRATE

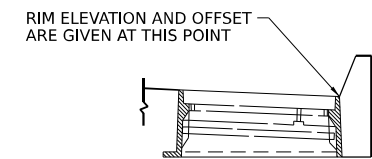

TYPE 11 FRAME & GRATE

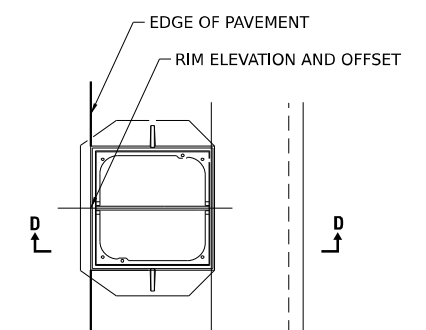

PLAN VIEW






SECTION D-D


TYPE 24 FRAME & GRATE

ROCK OUTLET PROTECTION

STRUCTURE ID	ALIGNMENT	STATION	OFFSET (FEET)		OUTLET SIZE (IN)	OUTLETTING TO	WIDTH US W1 (FEET)	WIDTH DS W2 (FEET)	LENGTH A (FEET)	LENGTH B (FEET)	LENGTH C (FEET)	TOTAL LENGTH La (FEET)	RIPRAP AREA - CLASS A4 (SQ YD)	FILTER FABRIC (SQ YD)
2172	US-6	217+25	54.2	RT	30	DITCH	7.5	15.6	0.6	8.0	3.5	12.1	15	15
2175	US-6	217+75	43.9	RT	38	DITCH	9.5	18.0	0.6	8.0	4.2	12.7	19	19
5085	RAMP A	508+49	122.2	RT	15	DITCH	36.0	36.0	2.6	10.0	2.6	15.2	61	61
1330	RAMP C	113+37	83.8	LT	15	DITCH	3.8	9.9	0.6	6.0	2.6	9.2	7	7

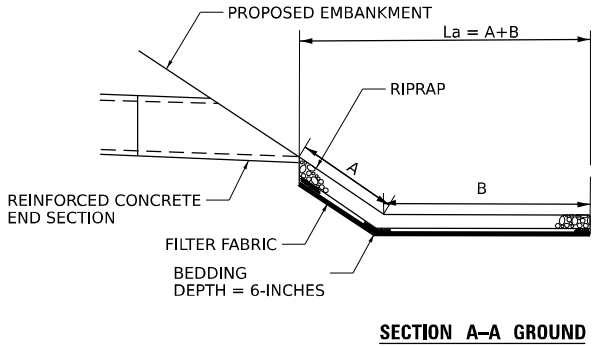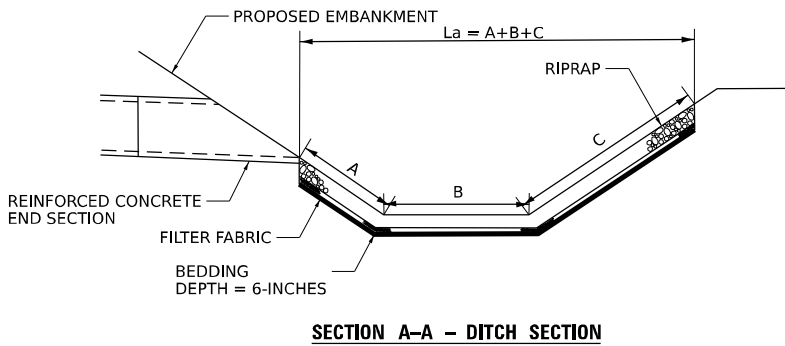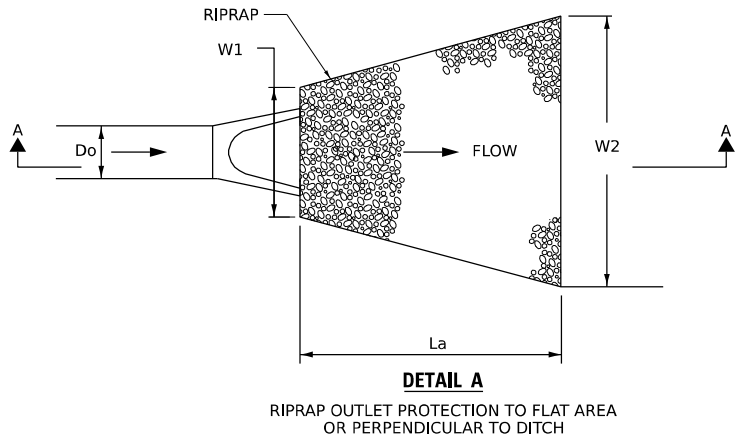

CONCRETE COLLAR DETAIL

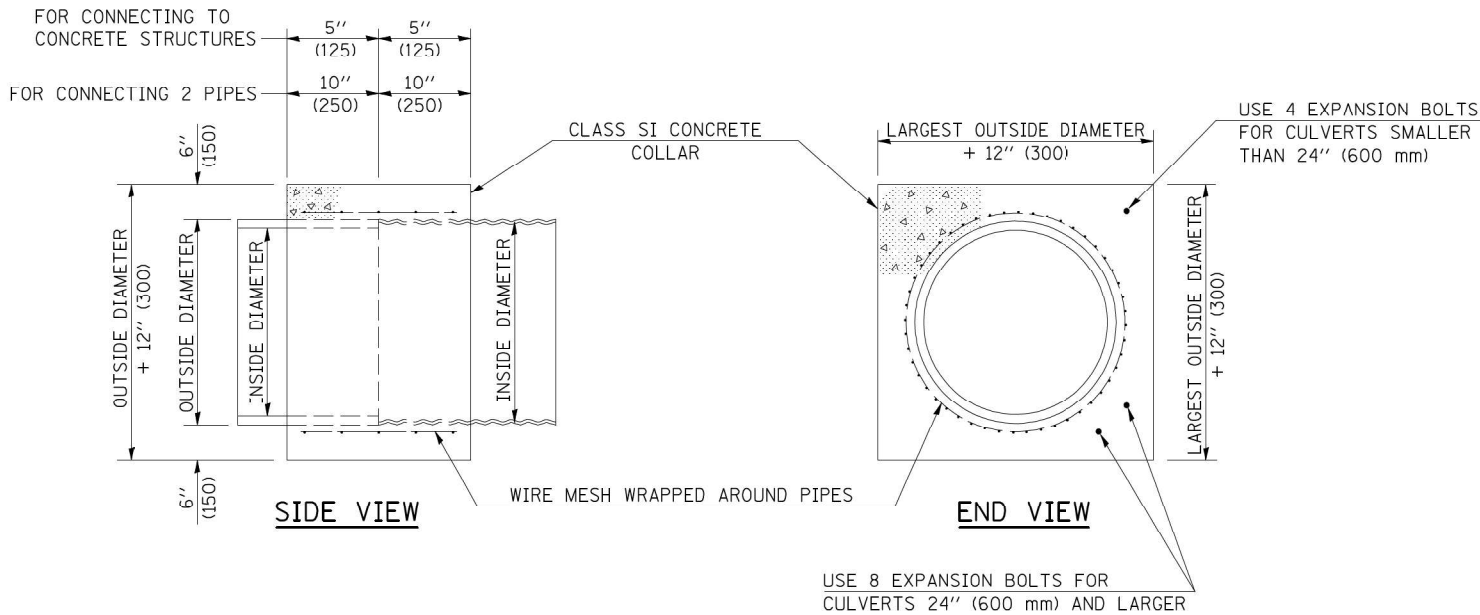

QUANTITIES FOR CONCRETE PIPES	
INSIDE DIAMETER OF PIPE	ESTIMATED CLASS SI CONCRETE REQUIRED
	20" (500 mm) WIDTH CU. YD. (m ³)
INCH (mm)	
4" (100)	0.14 (0.11)
6" (150)	0.16 (0.12)
8" (200)	0.19 (0.14)
10" (250)	0.22 (0.17)
12" (300)	0.25 (0.19)
15" (375)	0.30 (0.23)
18" (450)	0.35 (0.27)
24" (600)	0.45 (0.35)
30" (750)	0.57 (0.43)
36" (900)	0.69 (0.53)
42" (1050)	0.83 (0.63)
48" (1200)	0.97 (0.74)
54" (1350)	1.12 (0.86)
60" (1500)	1.28 (0.98)

QUANTITIES FOR METAL PIPES	
INSIDE DIAMETER OF PIPE	ESTIMATED CLASS SI CONCRETE REQUIRED
	20" (500 mm) WIDTH CU. YD. (m ³)
INCH (mm)	
4" (100)	0.12 (0.09)
6" (150)	0.14 (0.11)
8" (200)	0.16 (0.12)
10" (250)	0.19 (0.14)
12" (300)	0.21 (0.16)
15" (375)	0.25 (0.19)
18" (450)	0.29 (0.22)
24" (600)	0.38 (0.29)
30" (750)	0.47 (0.36)
36" (900)	0.59 (0.45)
42" (1050)	0.69 (0.53)
48" (1200)	0.81 (0.62)
54" (1350)	0.93 (0.71)
60" (1500)	1.05 (0.81)

GENERAL NOTES

- CLASS SI CONCRETE SHALL BE USED THROUGHOUT.
- WHEN CONCRETE COLLARS ARE USED TO CONNECT PIPES OF DIFFERENT OUTSIDE DIAMETERS, THE CONCRETE COLLAR SHALL BE FORMED USING THE LARGEST OUTSIDE DIAMETER (SEE END VIEW).
- THE WIRE MESH SHALL WEIGH NOT LESS THAN 54#/100 SQ. FT. (2.63 kg/m²).
- WHEN CONCRETE COLLARS ARE CONSTRUCTED ADJACENT TO AN EXISTING CONCRETE STRUCTURE (HEADWALLS, ETC.) EXPANSION BOLTS, SHALL BE USED AND WILL BE PAID FOR AT THE CONTRACT UNIT PRICE, EACH, FOR EXPANSION BOLTS OF THE SIZE SPECIFIED IN THE PLANS.
- CONCRETE COLLARS WILL BE PAID FOR AT THE CONTRACT UNIT PRICE, PER CUBIC YARD (CUBIC METER), FOR CONCRETE COLLARS INCLUDING ALL MATERIAL AND LABOR SPECIFIED TO COMPLETE THE WORK IN PLACE.
- ALL DIMENSIONS ARE IN INCHES (MILLIMETERS) UNLESS OTHERWISE SHOWN.

MODEL: Default
FILE NAME: p:\projects\trans\scorp\ppl\hatched\Documents\projects_2018\CH4001401180022\03-WSP\CD\62R23-RB-1-Sheets\Civil\0162R23-sh-detailed\RP.dgn




USER NAME = USHC706648	DESIGNED - AKG	REVISED -
	DRAWN - SSM	REVISED -
PLOT SCALE = 100,000' / in.	CHECKED - KS	REVISED -
PLOT DATE = 11/5/2025	DATE - 11/7/2025	REVISED -

STATE OF ILLINOIS
DEPARTMENT OF TRANSPORTATION


I-80
DRAINAGE DETAILS

SCALE: NONE SHEET 2 OF 4 SHEETS STA. TO STA.

F.A.I. RTE.	SECTION	COUNTY	TOTAL SHEETS	SHEET NO.
80	FAI 80 21 STRUCTURE 2	WILL	1230	384
CONTRACT NO. 62R23				
ILLINOIS FED. AID PROJECT				

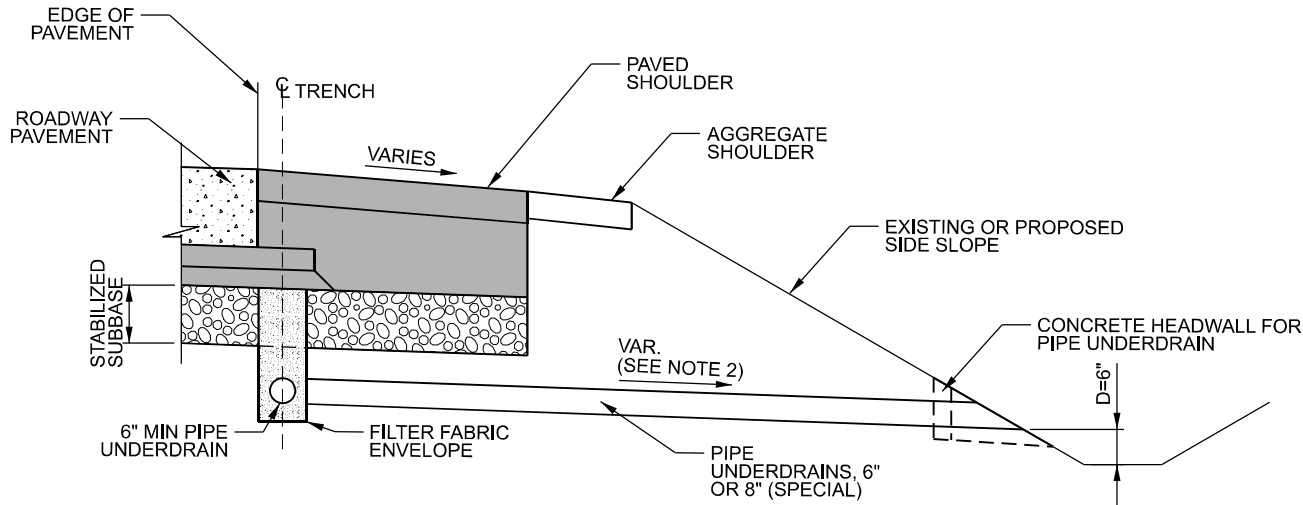

UNDERDRAIN OUTLET DETAILS

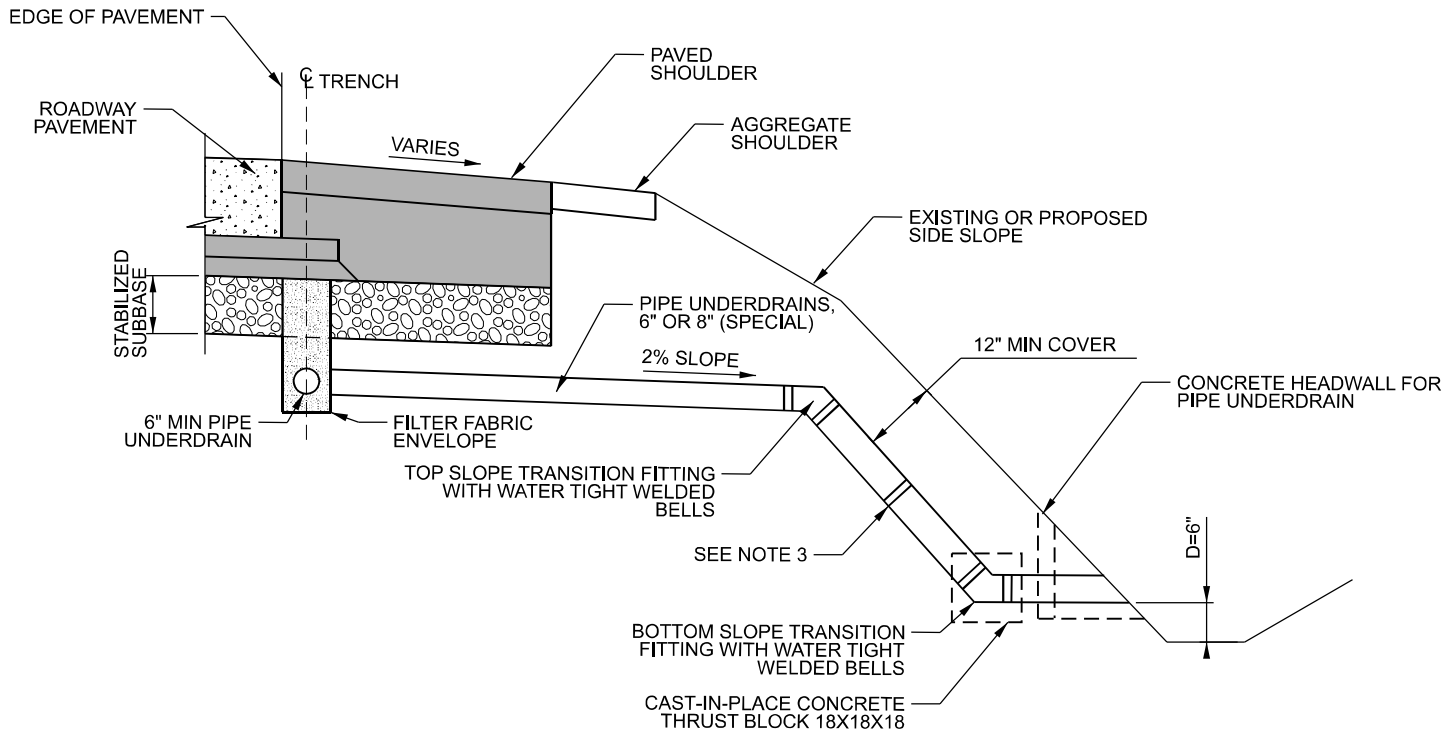

PIPE UNDERDRAIN OUTLET ON HIGH FILL SLOPE

NOTES:

- MODIFY IDOT HIGHWAY STANDARD 601001 AS SHOWN HEREON
- SLOPE OUTLET PIPE AS NEEDED TO MEET REQUIRED DEPTH, D, 6" MAX. IF REQUIRED SLOPE EXCEEDS 6%, PIPE UNDERDRAIN OUTLET ON HIGH FILL SLOPE DETAIL SHALL BE APPLIED.
- ALL JOINTS IN SLOPE DRAIN SYSTEM SHALL BE WATERTIGHT WITH A WELDED INTERNAL CYLINDER ON THE SPIGOT END OF THE PIPE. FIELD JOINTS SHALL BE WRAPPED WITH A DOUBLE WIDE MARMAC COUPLER, OR EQUIVALENT. PROVIDE CAST-IN-PLACE CONCRETE THRUST BLOCK AT BOTTOM SLOPE TRANSITION AS SHOWN. WORK AND MATERIALS SHALL BE INCLUDED IN PRICE OF PIPE UNDERDRAINS (SPECIAL) OF THE SIZE NOTED.
- ENGINEER TO CONSIDER NEED FOR OUTLET EROSION PROTECTION BASED ON LOCAL CONDITIONS.
- PIPE UNDERDRAINS SHALL BE INSTALLED ACCORDING TO SECTION 601 OF THE SSRBC AND STANDARD 601001-05. TOP OF PIPE UNDERDRAINS SHALL BE PLACED MINIMUM 6" BELOW THE AGGREGATE SUBGRADE IMPROVEMENT LAYER. THE COST OF MAKING PIPE UNDERDRAIN CONNECTIONS TO THE DRAINAGE STRUCTURES SHALL BE INCLUDED IN THE COST OF PIPE UNDERDRAINS.

LONGITUDINAL UNDERDRAINS									
PIPE UNDERDRAINS, TYPE 2, 6"									
FROM				TO				LENGTH (FT)	COMMENTS
ALIGNMENT	STATION	OFFSET		ALIGNMENT	STATION	OFFSET			
Ramp A	506+00	12.5	RT	Ramp A	507+00	12.5	RT	100	
Ramp A	507+02	12.5	RT	Ramp A	508+16	12.8	RT	114	
Ramp C	117+39	0.1	RT	Ramp C	116+50	0.4	RT	89	
Ramp C	116+48	0.4	RT	Ramp C	115+50	0.4	RT	98	
Ramp C	115+48	0.5	RT	Ramp C	114+50	0.4	RT	98	
Ramp C	114+47	0.5	RT	Ramp C	113+50	0.5	RT	97	

PIPE UNDERDRAINS, 6" SPECIAL										
ALIGNMENT	FROM STATION	OFFSET		TO STATION	OFFSET		OUTLETS TO STR.	INVERT	LENGTH (FT)	COMMENTS
Ramp A	507+00	12.5	RT	507+00	18.0	RT	DS6070	560.71	6	CONNECT TO TEMPORARY DRAINAGE STRUCTURE
Ramp A	508+18	12.8	RT	508+13	20.1	RT	IDS6081	557.16	8	
Ramp C	116+50	0.3	RT	116+50	6.8	RT	DS1651	556.27	7	
Ramp C	115+50	0.5	RT	115+50	9.0	RT	DS1550	553.77	9	
Ramp C	114+50	0.5	RT	114+50	9.0	RT	DS1450	552.50	9	
Ramp C	113+50	0.5	RT	113+50	9.0	RT	DS1350	551.32	9	

MODEL: Default
FILE NAME: p:\projects\trans\transcorp\ppl\hatched\Documents\Projects_2018\CH4001\401180022\03-WSP\CD\62R23-RB-1_Sheets\CD\62R23-sh-draindetail1B.dgn



WSP USA INC.
30 N. LASALLE STREET
SUITE 4200
CHICAGO, IL 60602
TEL: (312) 782-8150


USER NAME = USHC706648	DESIGNED - AKG	REVISED -
	DRAWN - SSM	REVISED -
PLOT SCALE = 100,000' / in.	CHECKED - KS	REVISED -
PLOT DATE = 11/5/2025	DATE - 11/7/2025	REVISED -

STATE OF ILLINOIS
DEPARTMENT OF TRANSPORTATION


I-80
DRAINAGE DETAILS

SCALE: NONE SHEET 3 OF 4 SHEETS STA. TO STA.


F.A.I. RTE.	SECTION	COUNTY	TOTAL SHEETS	SHEET NO.
80	FAI 80 21 STRUCTURE 2	WILL	1230	385
CONTRACT NO. 62R23				
ILLINOIS FED. AID PROJECT				

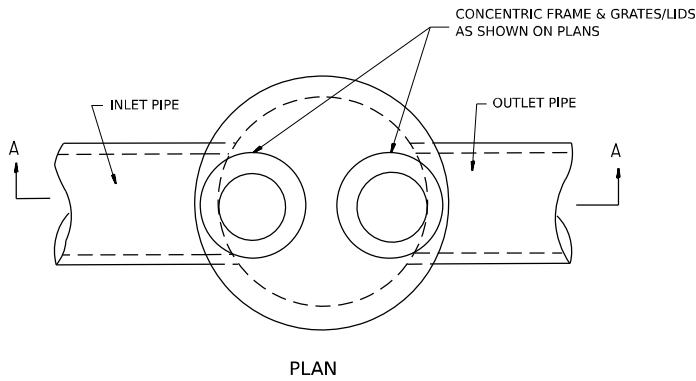


PLAN

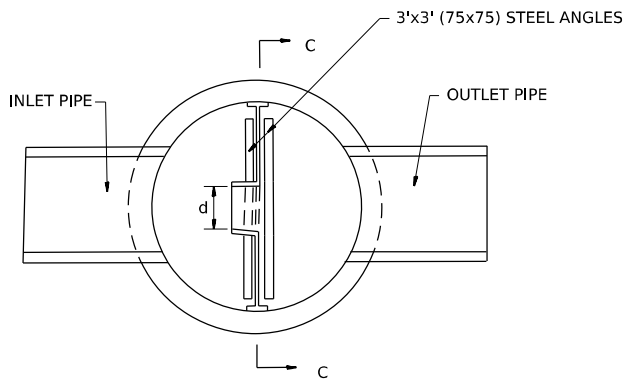


SECTION B-B

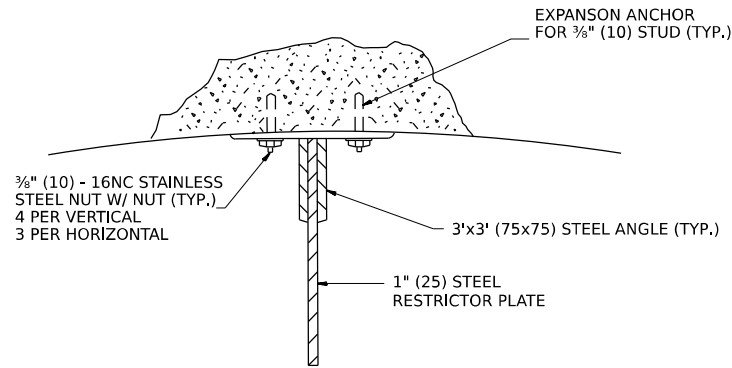

ANGLE FASTENER DETAIL

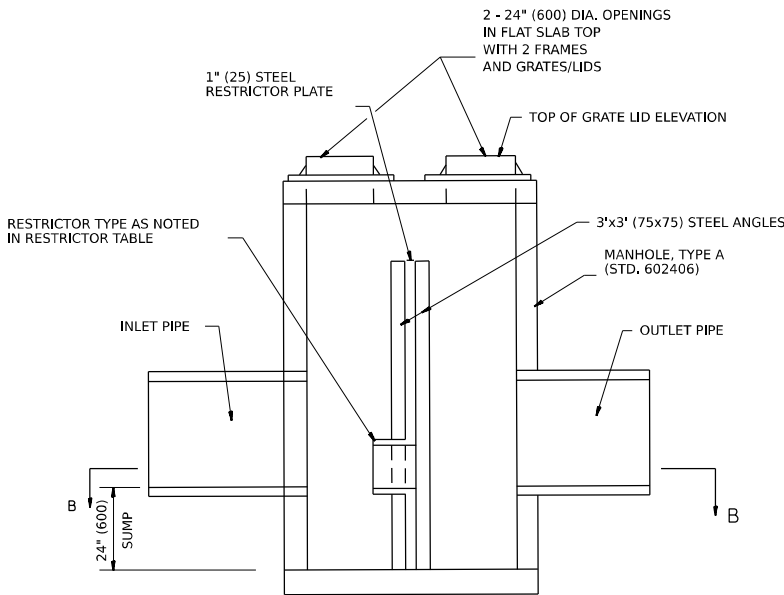


SECTION A-A

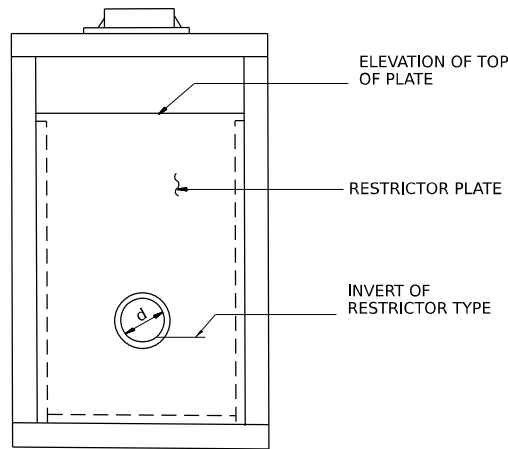

SECTION C-C


NOTES:

1. ALL STEEL ANGLES AND PLATES TO BE GALVANIZED AFTER FABRICATION.
2. ALL RESTRICTOR PLATES, ANGLES AND HARDWARE TO BE INCLUDED IN THE COST OF THE MANHOLE.
3. BASIS OF PAYMENT: "MANHOLES, TYPE A, 7'-DIAMETER, WITH 2 TYPE 1 FRAMES, CLOSED LID, RESTRICTOR PLATE" EACH

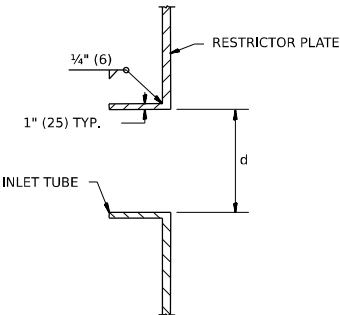

INLET TUBE DETAIL

STR. NO.	ALIGNMENT	STATION	OFFSET	MANHOLE DIAMETER	FRAME AND GRATE	RESTRICTOR TYPE	INSIDE RESTRICTOR TYPE DIAMETER in. (mm) (d)	INVERT OF RESTRICTOR TYPE	ELEVATION OF TOP OF PLATE OVERFLOW
IDS-5087	RAMP A	508+93	124.0' RT	6 FT	2-T1 F&G CL	2	4.0	520.00	523.00

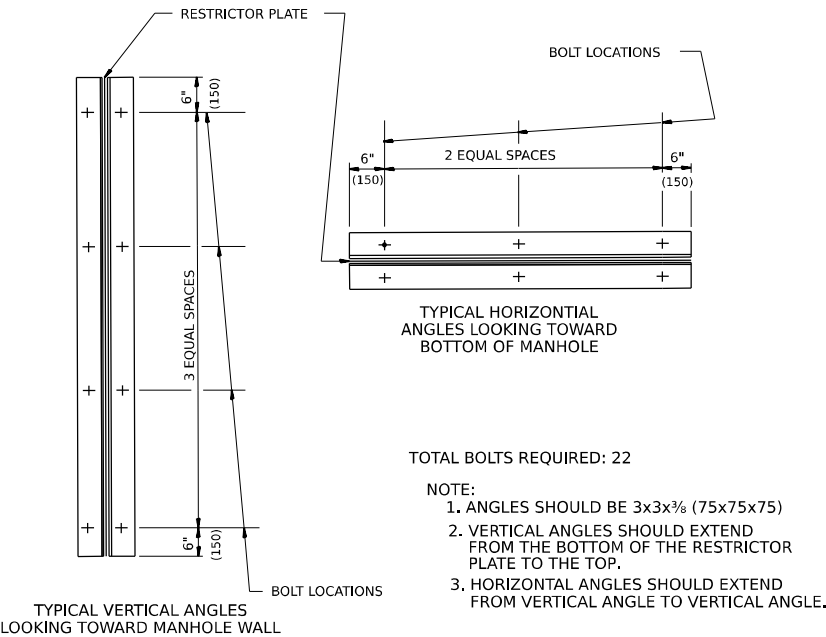

STEEL ANGLE BOLTING DETAILS

RESTRICTOR TYPE					
1	2	3	4	5	6
RE-ENTRANT TUBE	SHARP EDGED	SQUARE EDGED	RE-ENTRANT TUBE	SQUARE EDGED	ROUNDED
LENGTH: 1/2 TO 1 DIA.		STREAM CLEARS SIDES	LENGTH: 2-1/2 DIA.	LENGTH: 2-1/2 DIA.	
C=.52	C=.61	C=.61	C=.73	C=.82	C=.98

VALUES OF "C" FOR CIRCULAR AND SQUARE ORIFICES

TOTAL BOLTS REQUIRED: 22

NOTE:

1. ANGLES SHOULD BE 3x3x3/8 (75x75x75)
2. VERTICAL ANGLES SHOULD EXTEND FROM THE BOTTOM OF THE RESTRICTOR PLATE TO THE TOP.
3. HORIZONTAL ANGLES SHOULD EXTEND FROM VERTICAL ANGLE TO VERTICAL ANGLE.

ALL DIMENSIONS ARE IN INCHES (MILLIMETERS) UNLESS OTHERWISE SHOWN.

Model: Default
File Name: p:\projects\trans\scorp-pw\hatched\Documents\projects_2018\CH4001401180022\03-WSP\CAD\62R23-RB-1-Sheets\Civil\62R23-sh-cv-drainedalk.dgn



WSP USA INC.
30 N. LA SALLE STREET
SUITE 4200
CHICAGO, IL 60602
TEL: (312) 782-8150

USER NAME = USHC706648	DESIGNED - SP	REVISED -
	DRAWN - AD	REVISED -
PLOT SCALE = 0.167 " / in.	CHECKED - KS	REVISED -
PLOT DATE = 11/5/2025	DATE - 11/7/2025	REVISED -


STATE OF ILLINOIS
DEPARTMENT OF TRANSPORTATION

I-80
DRAINAGE DETAILS


SCALE: NONE SHEET 4 OF 4 SHEETS STA. TO STA.

F.A.I. RTE.	SECTION	COUNTY	TOTAL SHEETS	SHEET NO.
80	FAI 80 21 STRUCTURE 2	WILL	1230	386
CONTRACT NO. 62R23				
ILLINOIS FED. AID PROJECT				

Model: Default
File Name: p:\projects\trans\trans-corp-pw-bentley.com\trans\corp-pw-hosted\Documents\Projects_2018\CH401\401180022\03-WSP\CAD\62023-RR-1-Sheets\Civil\62R23-shr-dimanded\US6-cbcl.dgn

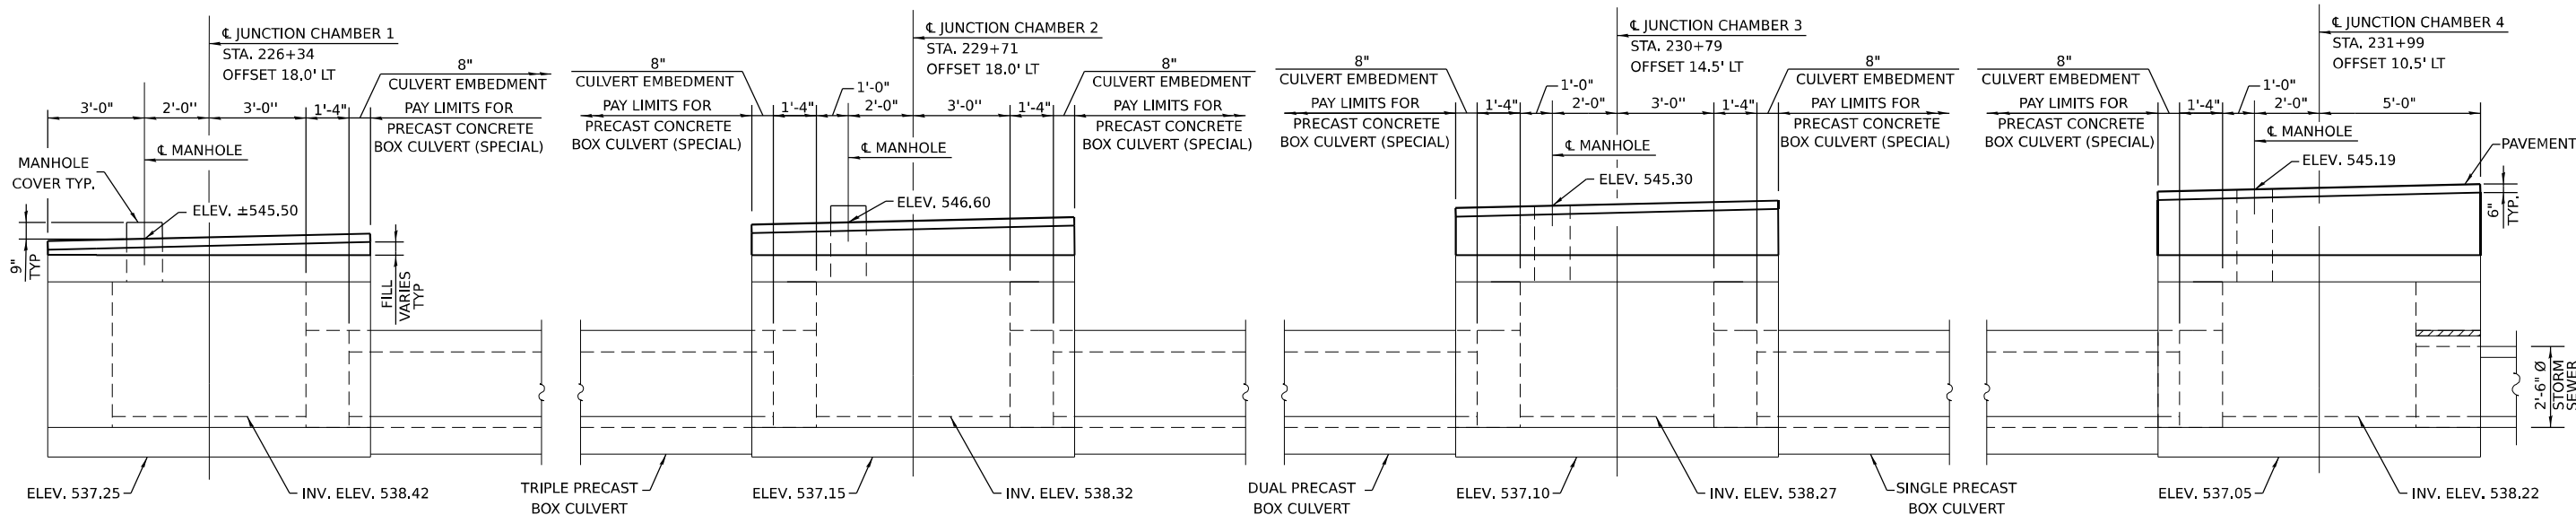


PRECAST CONCRETE BOX CULVERT (SPECIAL) ELEVATION

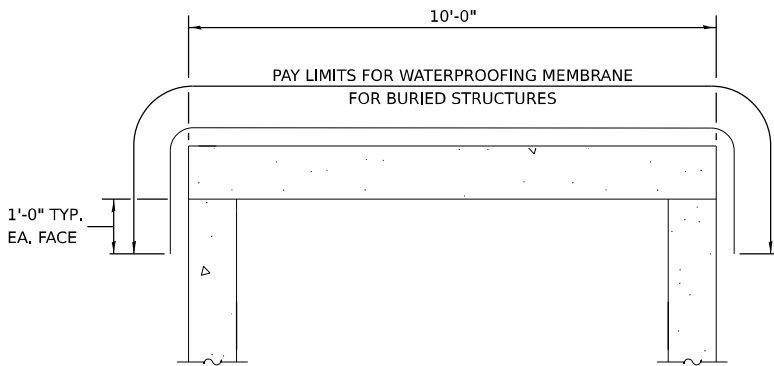

SECTION THRU JUNCTION CHAMBER

BILL OF MATERIAL

ITEM	UNIT	QUANTITY
PRECAST CONCRETE BOX CULVERT (SPECIAL)	FOOT	535
MEMBRANE WATERPROOFING SYSTEM FOR BURIED STRUCTURES	SQ YD	124
STRUCTURE EXCAVATION	CU YD	2333
ROCK EXCAVATION FOR STRUCTURES	CU YD	1247
JUNCTION CHAMBER NO. 1	EACH	1
JUNCTION CHAMBER NO. 2	EACH	1
JUNCTION CHAMBER NO. 3	EACH	1
JUNCTION CHAMBER NO. 4	EACH	1

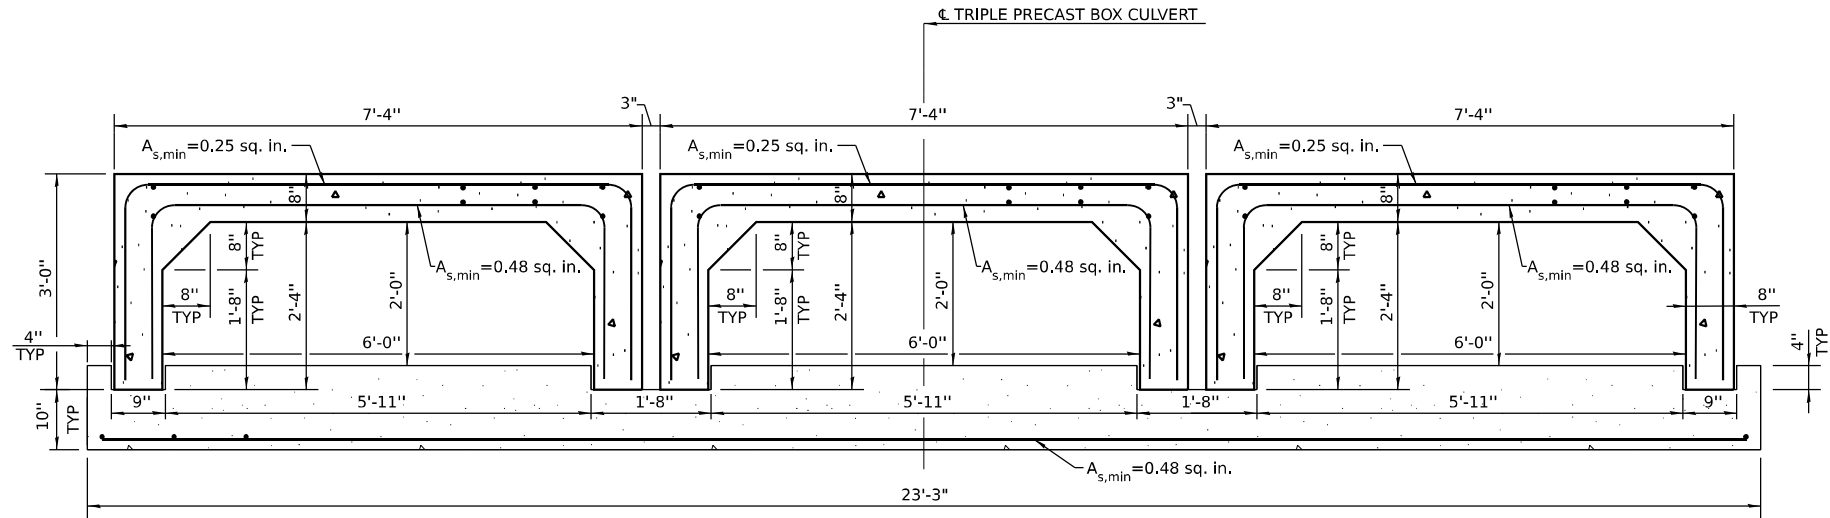

SECTION THRU TRIPLE PRECAST BOX CULVERT

PRECAST GENERAL NOTES

PRECAST CONCRETE BOX CULVERT (SPECIAL) SHALL CONFORM TO THE REQUIREMENTS OF ARTICLE 540.06 OF THE STANDARD SPECIFICATIONS, THE APPLICABLE REQUIREMENTS OF AASHTO M259 AND ASTM C1577.

THE MINIMUM PRECAST CONCRETE STRENGTH SHALL BE 5,000 PSI.

LIFTING HOLES SHALL BE FILLED WITH CONCRETE PLUGS AND MASTIC AFTER THE BOX SECTIONS ARE IN PLACE.

THE DESIGN FILL HEIGHT IS 5.0 FEET.

COVER FROM THE FACE OF PRECAST CONCRETE REINFORCEMENT BARS SHALL BE 1".

THE REINFORCEMENT BAR AREAS SHOWN ON THIS PLAN SHEET ARE BASED ON WELDED WIRE REINFORCEMENT (WWR). THE CONTRACTOR MAY USE STEEL REINFORCEMENT BARS IN LIEU OF WWR. REINFORCEMENT BARS SHALL BE LIMITED TO THE SIZES OF #3 AND #4 BARS, AND HAVE A MAXIMUM SPACING OF 4". THE REINFORCEMENT AREAS SHOWN ON THIS PLAN SHEET SHALL BE INCREASED TO ACCOUNT FOR THE DIFFERENCE IN STEEL YIELD STRENGTH IN ACCORDANCE WITH ASTM C1577, SECTION 12.6.

CAST-IN-PLACE BARREL AND/OR BASE SECTION IS NOT ALLOWED.

JOINTS TO BE SEALED AND ALL VOIDS FILLED WITH A MASTIC JOINT SEALER PER ARTICLE 540.06.

Model: Default
File Name: p:\projects\trans\trans-stone-pw-bentley.com\trans\scorp-pw\hosted\Documents\Projects_2018\CH401\401180022\03-WSP\CAD\62R23-RB-1-Sheets\Civil\02R23-shr-dimanded\US6-coc3.dgn



WSP USA INC.

30 N. LA SALLE STREET

SUITE 4200

CHICAGO, IL 60602

TEL: (312) 782-8150

USER NAME	= USSJ696614	DESIGNED -	TB/MHD	REVISED -	
		DRAWN -	TB/MHD	REVISED -	
PLOT SCALE	= 5:4,0000 " = 1" / in.	CHECKED -	LAS	REVISED -	
PLOT DATE	= 11/6/2025	DATE	= 11/7/2025	REVISED -	

STATE OF ILLINOIS

DEPARTMENT OF TRANSPORTATION

DRAINAGE DETAILS – US 6 COMPENSATORY STORAGE STRUCTURE


PRECAST REINFORCED CONCRETE BOX CULVERT

SCALE: NONE

SHEET 3 OF 11 SHEETS

STA. TO STA.



F.A.I. RTE.	SECTION	COUNTY	TOTAL SHEETS	SHEET NO.
80	FAI 80 21 STRUCTURE 2	WILL	1230	389
CONTRACT NO. 62R23				
ILLINOIS FED. AID PROJECT				

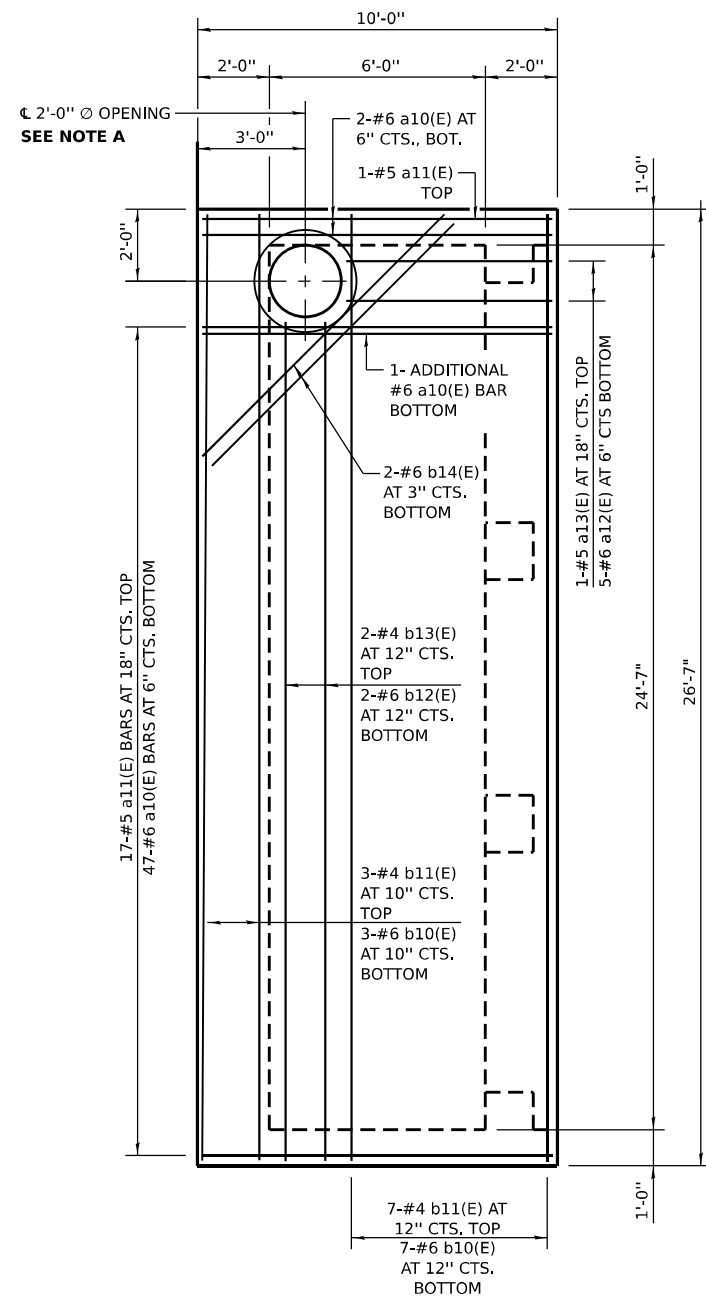


TOP SLAB PLAN

NOTE A

 
PROVIDE A 2'-11" Ø 1" DEEP RECESS IN THE TOP SLAB, CENTERED OVER THE 2'-0" OPENING, FOR THE FRAME AND LID. FRAME SHALL BE SET ON AN INITIAL $\frac{3}{8}$ " MIN. GROUT BED (2:1 SAND AND PORTLAND CEMENT, VERY DRY MIX) TO MATCH RIM ELEVATION SHOWN ON DRAINAGE PLANS.

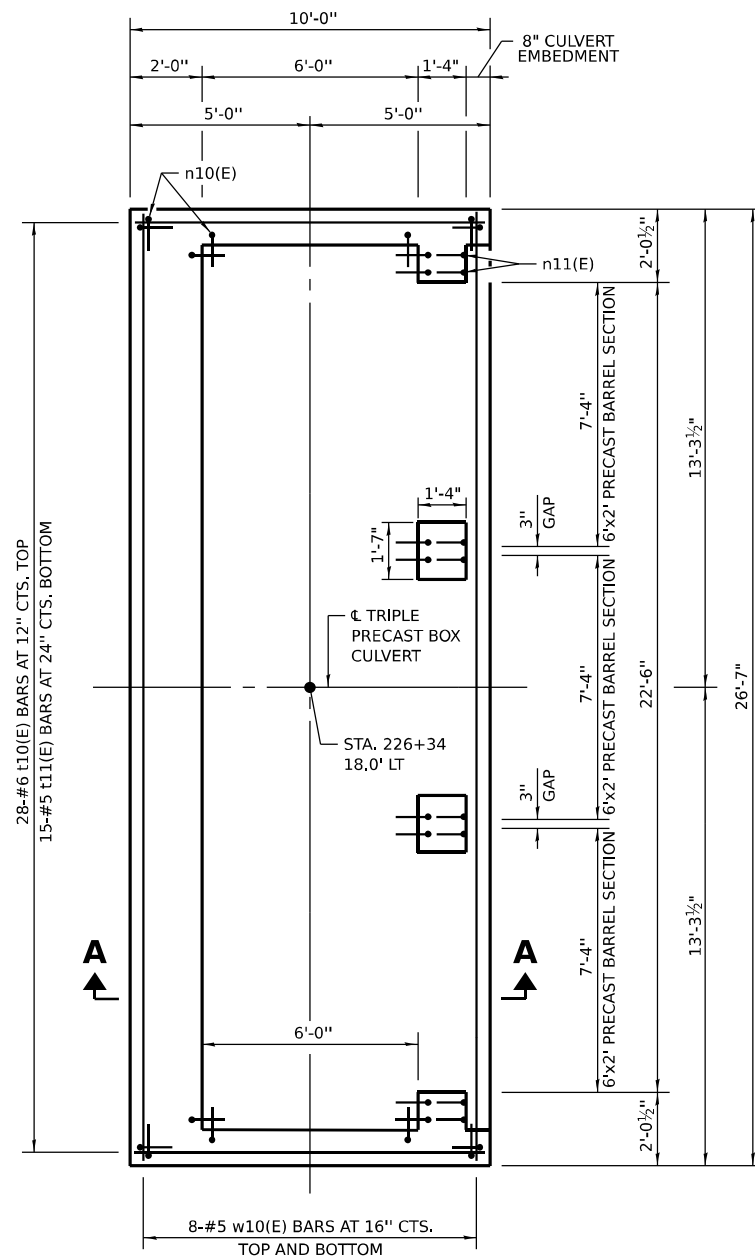

BOTTOM SLAB PLAN

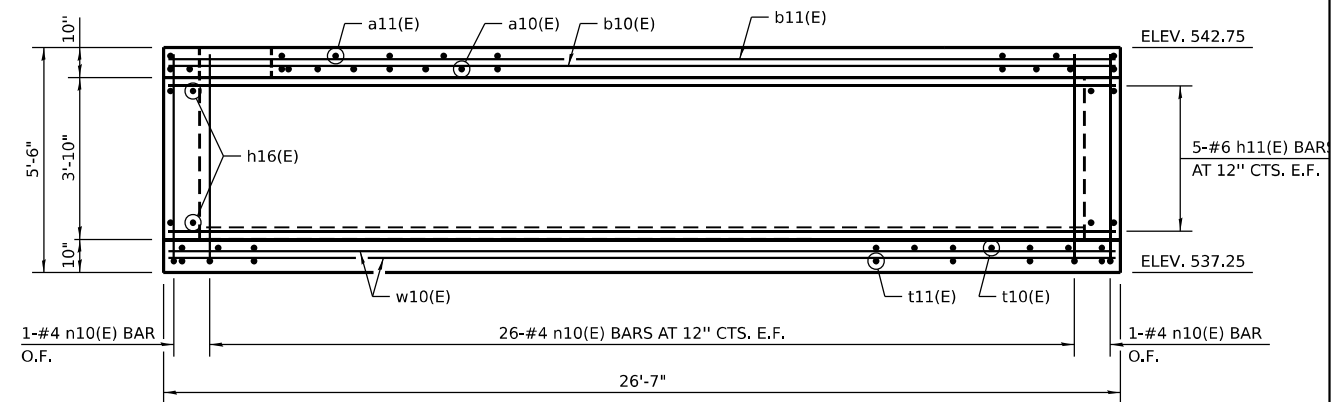

SOUTH WALL ELEVATION

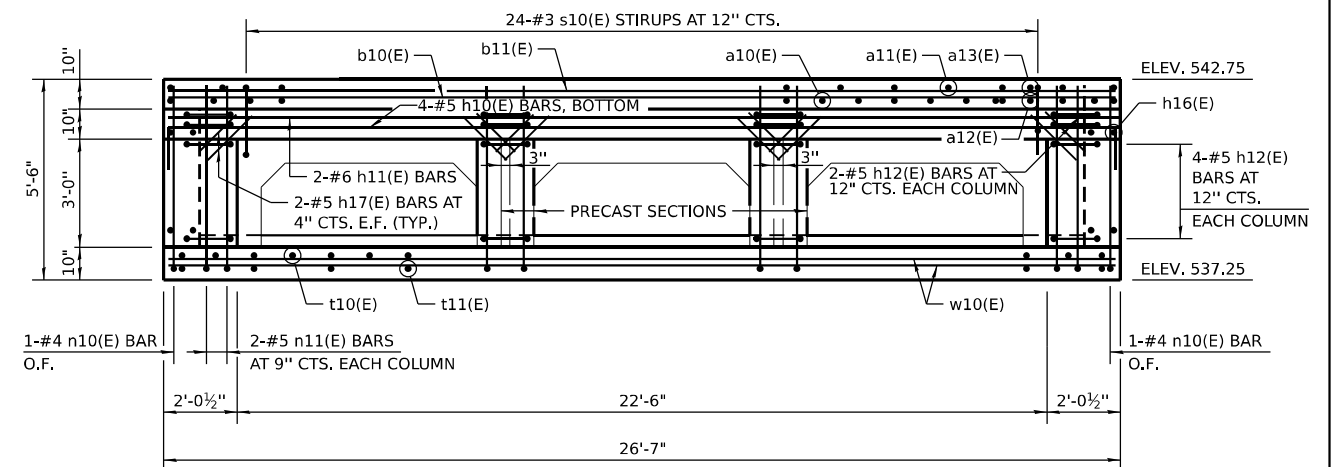

NORTH WALL ELEVATION

NOTES

REINFORCEMENT BARS DESIGNATED (E) SHALL BE EPOXY COATED.

SEE SHEET 391 FOR SECTION A-A, ADDITIONAL
ELEVATIONS AND DETAILS.

SEE SHEET 389 FOR TRIPLE PRECAST BOX CULVERT
DETAILS.

LEGEND

E.F.	EACH FACE
I.F.	INSIDE FACE
O.F.	OUTSIDE FACE

BILL OF MATERIAL
(FOR INFORMATION ONLY)


BAR	NO.	SIZE	LENGTH	SHAPE
a10(E)	50	#6	11'-0"	
a11(E)	18	#5	9'-8"	
a12(E)	5	#6	7'-0"	
a13(E)	1	#5	5'-8"	
b10(E)	10	#6	26'-3"	
b11(E)	10	#4	26'-3"	
b12(E)	2	#6	23'-3"	
b13(E)	2	#4	23'-3"	
b14(E)	2	#6	9'-6"	
h10(E)	4	#5	28'-0"	
h11(E)	12	#6	26'-3"	
h12(E)	24	#5	5'-5"	
h16(E)	20	#6	9'-8"	
h17(E)	24	#5	2'-0"	
n10(E)	92	#4	5'-10"	
n11(E)	16	#5	6'-0"	
s10(E)	24	#3	6'-9"	
t10(E)	28	#6	11'-0"	
t11(E)	15	#5	9'-8"	
w10(E)	16	#5	26'-3"	
* REINFORCEMENT BARS, EPOXY COATED			POUND	4400
* CONCRETE STRUCTURES			CU YD	28.5
* FRAMES AND LIDS, TYPE 1, OPEN LID			EACH	1
* CAST IRON STEPS			EACH	3

NOTES


- REINFORCEMENT BARS DESIGNATED (E) SHALL BE EPOXY COATED.
- SEE SHEET 389 FOR TRIPLE PRECAST BOX CULVERT DETAILS.
- SEE STANDARD 602701 FOR DETAILS OF CAST IRON STEPS.
- SEE STANDARD 604001 FOR DETAILS OF FRAME AND LID.
- THE JUNCTION CHAMBER AT STATION 226+34 WILL BE PAID FOR AS JUNCTION CHAMBER NO. 1.
- * INCLUDED IN THE COST OF JUNCTION CHAMBER NO. 1.

LEGEND

 
- E.F. EACH FACE
I.F. INSIDE FACE
O.F. OUTSIDE FACE



BARS a10(E), a12(E)
& t10(E)

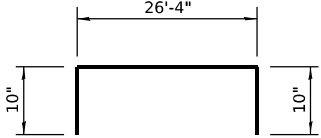


BAR h10(E)

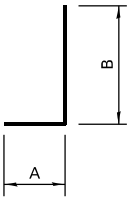


BAR	A	B
n10(E)	8"	5'-2"
n11(E)	10"	5'-2"

BARS n10(E) & n11(E)

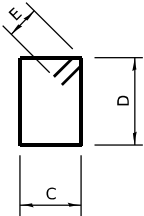


BAR	C	D	E
h12(E)	1'-0"	1'-3"	5½"
s10(E)	1'-8"	1'-4"	4½"

BARS h12(E) & s10(E)

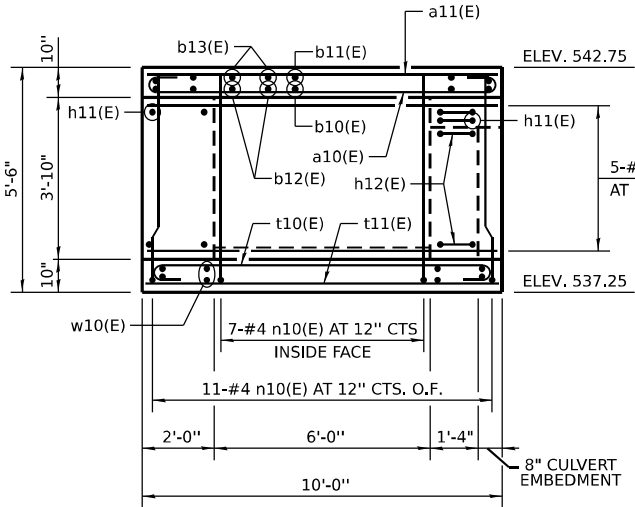


EAST WALL ELEVATION

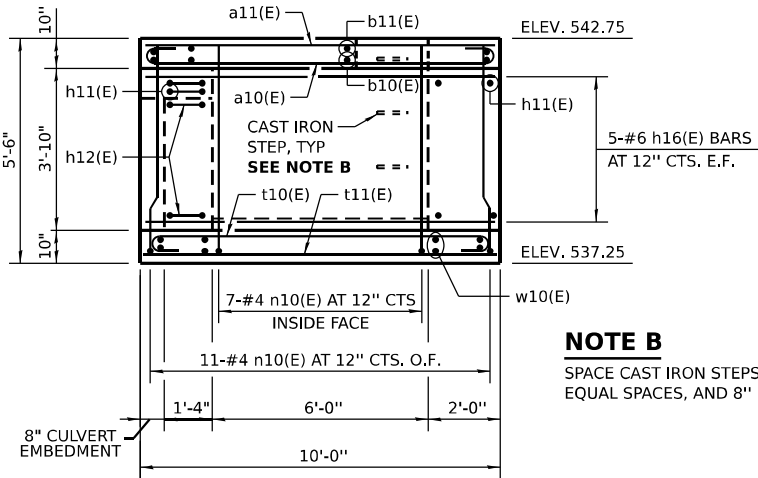

WEST WALL ELEVATION

NOTE B

SPACE CAST IRON STEPS AT 12" TO 18", EQUAL SPACES, AND 8" FROM TOP OF SLAB.

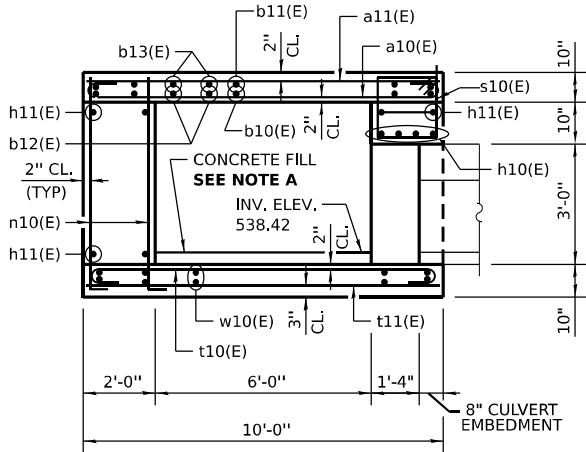

SECTION A-A

NOTE A

PLACE CONCRETE FILL AFTER INSTALLATION OF BOX CULVERT AND JUNCTION CHAMBER WALLS. MATCH TOP OF FILL ELEVATION TO BOX CULVERT INVERT ELEVATION 539.01.

Model: Default
File Name: p:\projects\trans\scorp\ppl\hosted\Documents\Projects_2018\CH4001\401180022\03-WSP\CH401\DWG\22-62R23-shr-dimanded.dwg, US6-UC12.dgn



WSP USA INC.
30 N. LASALLE STREET
SUITE 4200
CHICAGO, IL 60602
TEL: (312) 782-8150

USER NAME = USSJ696614	DESIGNED - TB/MHD	REVISED -
	DRAWN - TB/MHD	REVISED -
PLOT SCALE = 5/4,0000 " = 1"	CHECKED - LAS	REVISED -
PLOT DATE = 11/6/2025	DATE - 11/7/2025	REVISED -


STATE OF ILLINOIS
DEPARTMENT OF TRANSPORTATION

DRAINAGE DETAILS – US 6 COMPENSATORY STORAGE STRUCTURE
JUNCTION CHAMBER 1 – STA. 226+34 (2 OF 2)


SCALE: NONE SHEET 5 OF 11 SHEETS STA. 226+34 TO STA. 226+34

F.A.I. RTE.	SECTION	COUNTY	TOTAL SHEETS	SHEET NO.
80	FAI 80 21 STRUCTURE 2	WILL	1230	391
CONTRACT NO. 62R23				
ILLINOIS FED. AID PROJECT				


Model: Default
File Name: p:\projects\trans\transcorp\ppl-hosted\Documents\Projects_2018\CH4001401180022\03-WSP\CD\6262023-RB-1-Sheets\Civil\02R23-shr-drainedallUS6-1c21.dgn

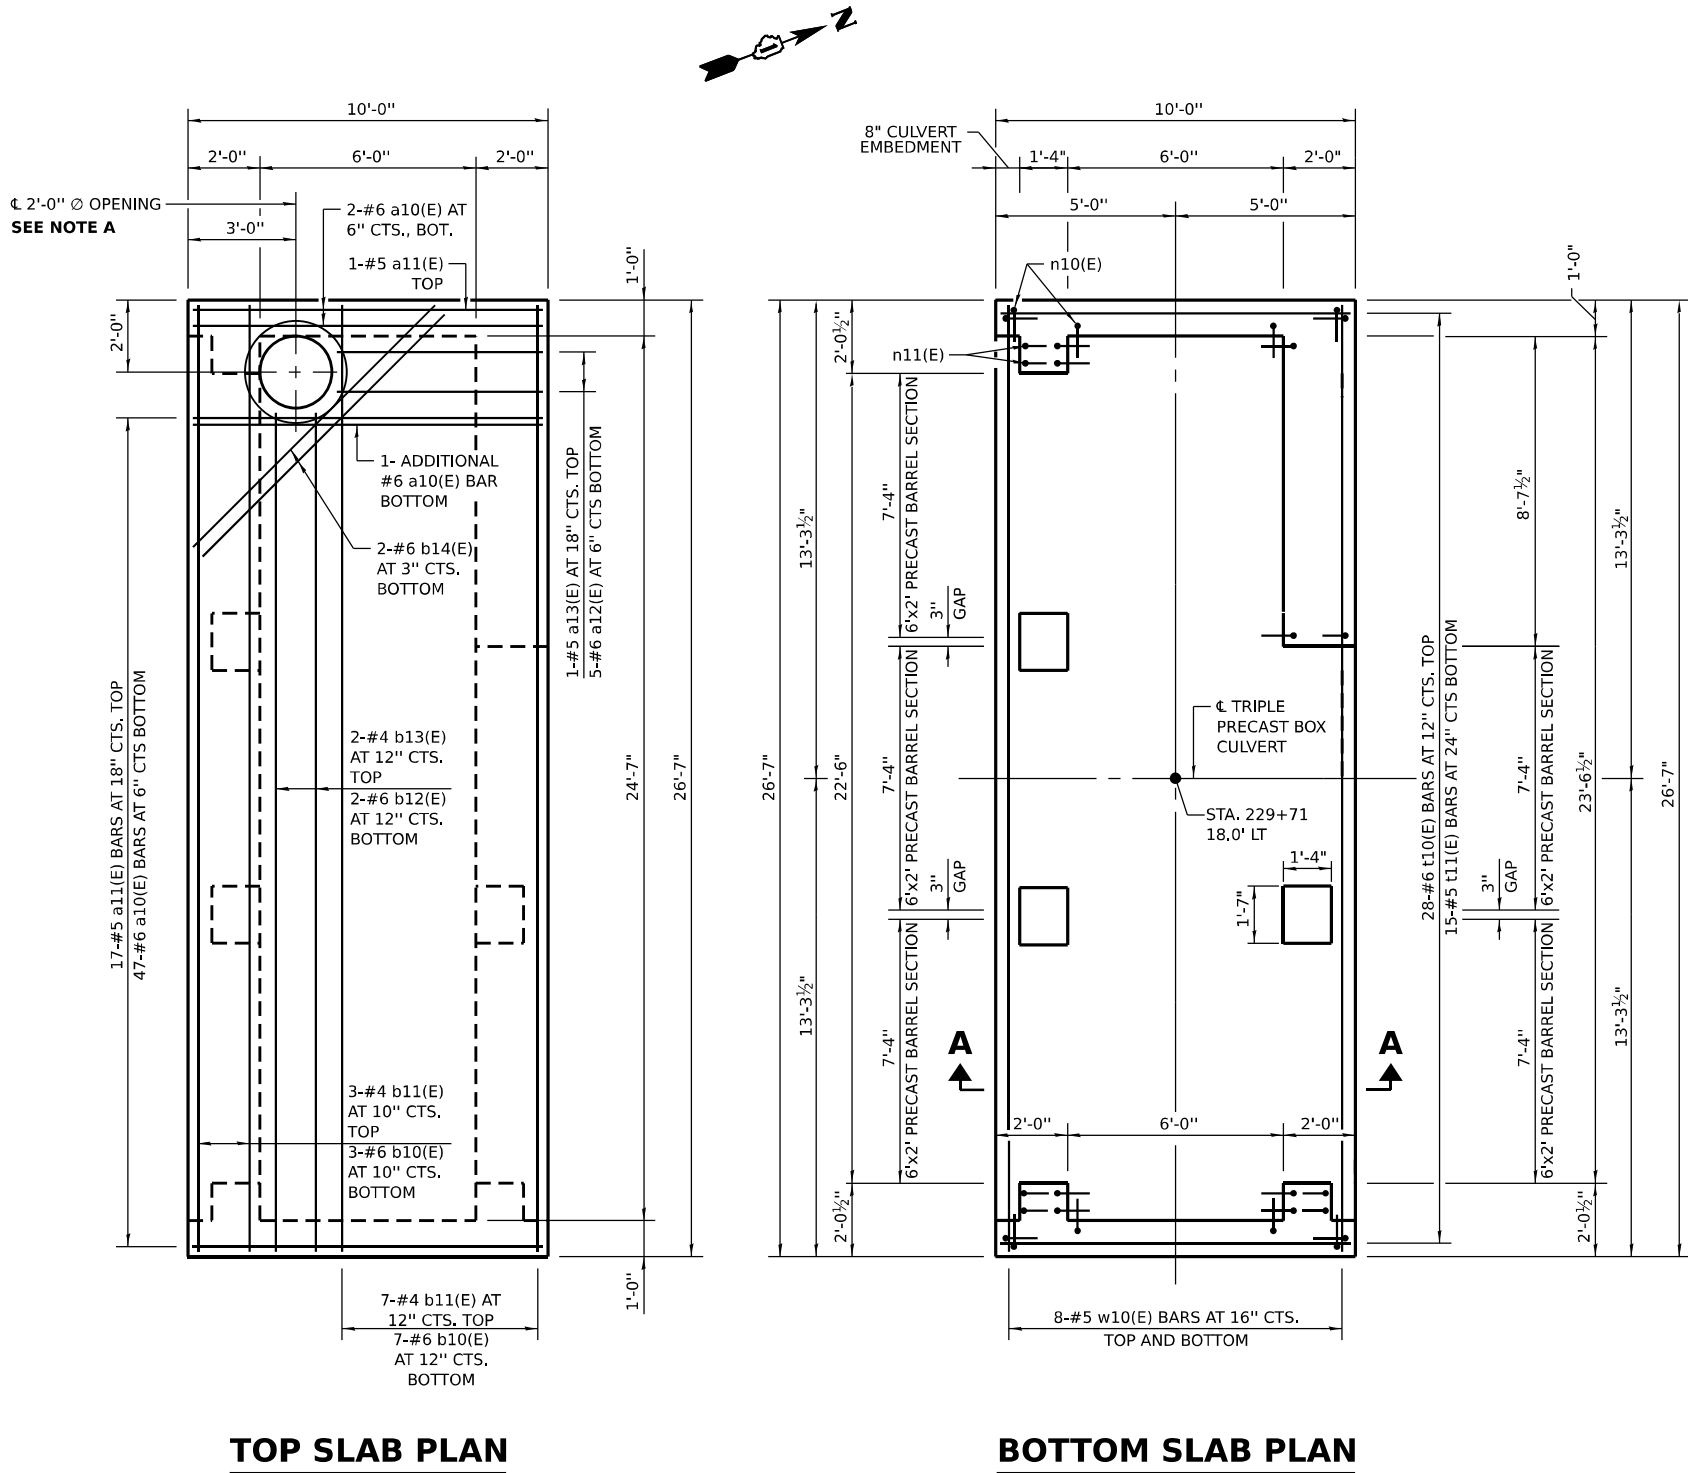

NOTE A
PROVIDE A 2'-11" Ø 1" DEEP RECESS IN THE TOP SLAB, CENTERED OVER THE 2'-0" OPENING, FOR THE FRAME AND LID. FRAME SHALL BE SET ON AN INITIAL 3/8" MIN. GROUT BED (2:1 SAND AND PORTLAND CEMENT, VERY DRY MIX) TO MATCH RIM ELEVATION SHOWN ON DRAINAGE PLANS.

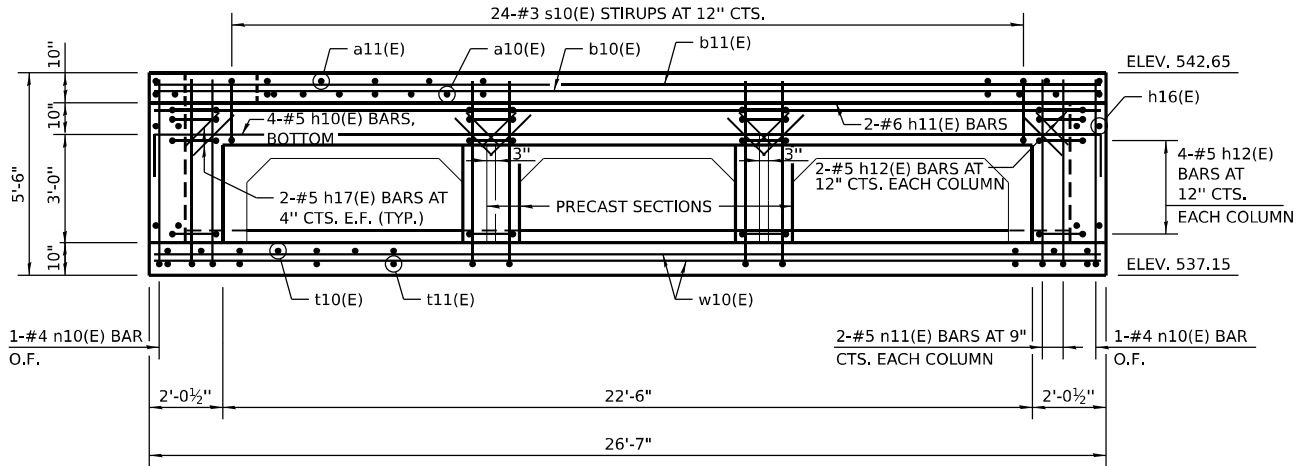

SOUTH WALL ELEVATION

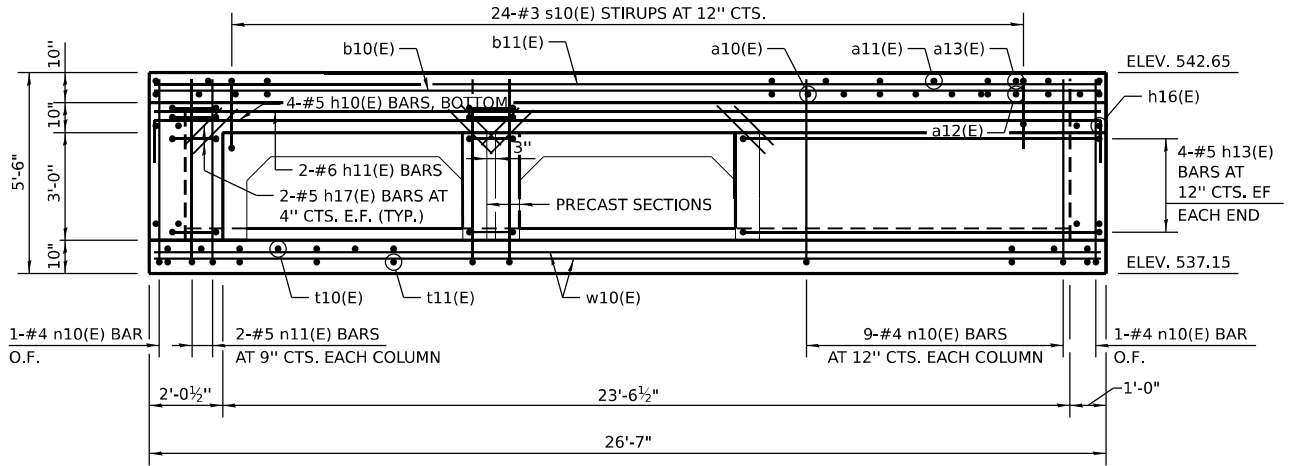

NORTH WALL ELEVATION

LEGEND

- E.F. EACH FACE
- I.F. INSIDE FACE
- O.F. OUTSIDE FACE

NOTES

REINFORCEMENT BARS DESIGNATED (E) SHALL BE EPOXY COATED.
SEE SHEET 393 FOR SECTION A-A, ADDITIONAL ELEVATIONS AND DETAILS.
SEE SHEET 389 FOR TRIPLE PRECAST BOX CULVERT DETAILS.



WSP USA INC.
30 N. LASALLE STREET
SUITE 4200
CHICAGO, IL 60602
TEL: (312) 782-8150

USER NAME	= USSJ696614
PLOT SCALE	= 5:4,0000 '"/>

DESIGNED -	TB/MHD
DRAWN -	TB/MHD
CHECKED -	LAS
DATE -	11/7/2025

REVISED -	
REVISED -	
REVISED -	
REVISED -	

STATE OF ILLINOIS
DEPARTMENT OF TRANSPORTATION

DRAINAGE DETAILS – US 6 COMPENSATORY STORAGE STRUCTURE
JUNCTION CHAMBER 2 – STA. 229 + 71 (1 OF 2)

SCALE: NONE SHEET 6 OF 11 SHEETS STA. 229+71 TO STA. 229+71


F.A.I. RTE.	SECTION	COUNTY	TOTAL SHEETS	SHEET NO.
80	FAI 80 21 STRUCTURE 2	WILL	1230	392
CONTRACT NO. 62R23				
ILLINOIS FED. AID PROJECT				

BILL OF MATERIAL
(FOR INFORMATION ONLY)


BAR	NO.	SIZE	LENGTH	SHAPE
a10(E)	50	#6	11'-0"	
a11(E)	18	#5	9'-8"	
a12(E)	5	#6	7'-0"	
a13(E)	1	#5	5'-8"	
b10(E)	10	#6	26'-3"	
b11(E)	10	#4	26'-3"	
b12(E)	2	#6	23'-3"	
b13(E)	2	#4	23'-3"	
b14(E)	2	#6	9'-6"	
h10(E)	8	#5	28'-0"	
h11(E)	4	#6	26'-3"	
h12(E)	36	#5	5'-5"	
h13(E)	8	#5	9'-3"	
h16(E)	20	#6	9'-8"	
h17(E)	40	#5	2'-0"	
n10(E)	58	#4	5'-10"	
n11(E)	24	#5	6'-0"	
s10(E)	48	#3	6'-9"	
t10(E)	28	#6	11'-0"	
t11(E)	15	#5	9'-8"	
w10(E)	16	#5	26'-3"	
* REINFORCEMENT BARS, EPOXY COATED			POUND	4360
* CONCRETE STRUCTURES			CU YD	25.3
* FRAMES AND LIDS, TYPE 1, OPEN LID			EACH	1
* CAST IRON STEPS			EACH	3

NOTES

- REINFORCEMENT BARS DESIGNATED (E) SHALL BE EPOXY COATED.
- SEE SHEET 391 FOR BAR BENDING DETAILS.
- PROVIDE A 24" INSIDE DIA. CONCRETE ADJUSTING RING OF THE THICKNESS REQUIRED TO SET THE RIM TO THE ELEVATION SHOWN ON THE DRAINAGE PLANS. COST INCLUDED WITH THE JUNCTION CHAMBER PAY ITEM.
- SEE SHEET 389 FOR TRIPLE PRECAST BOX CULVERT DETAILS.
- SEE STANDARD 602701 FOR DETAILS OF CAST IRON STEPS.
- SEE STANDARD 604001 FOR DETAILS OF FRAME AND LID.
- THE JUNCTION CHAMBER AT STATION 229+71 WILL BE PAID FOR AS JUNCTION CHAMBER NO. 2.
- * INCLUDED IN THE COST OF JUNCTION CHAMBER NO. 2.

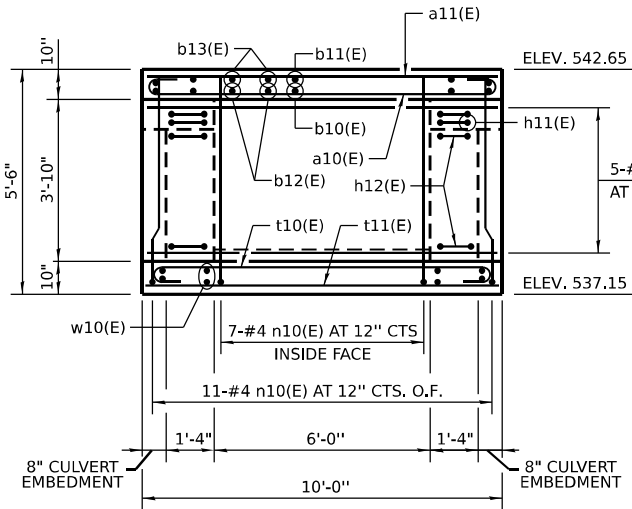


EAST WALL ELEVATION

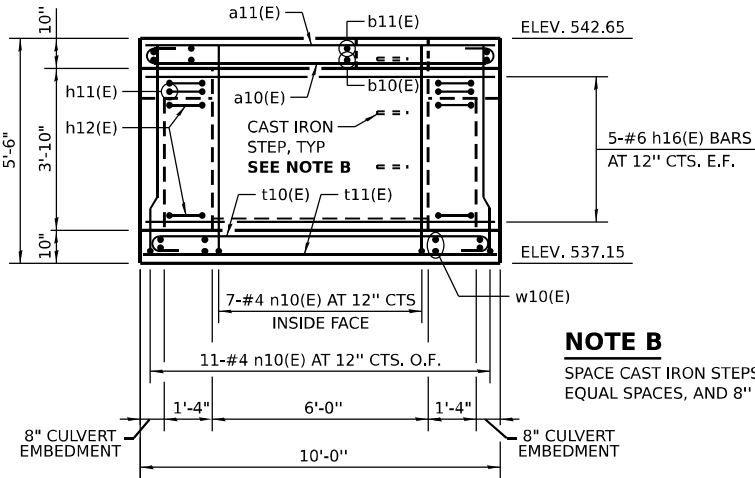

WEST WALL ELEVATION

NOTE B

SPACE CAST IRON STEPS AT 12" TO 18", EQUAL SPACES, AND 8" FROM TOP OF SLAB.

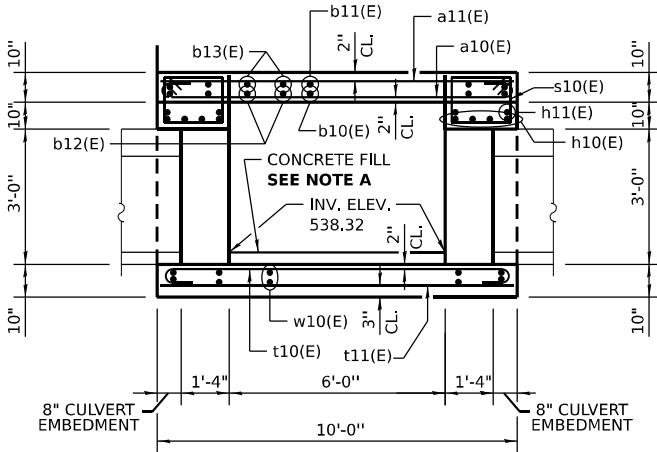

SECTION A-A

NOTE A

PLACE CONCRETE FILL AFTER INSTALLATION OF BOX CULVERT AND JUNCTION CHAMBER WALLS. MATCH TOP OF FILL ELEVATION TO BOX CULVERT INVERT ELEVATION 538.91.

LEGEND

- E.F. EACH FACE
 I.F. INSIDE FACE
 O.F. OUTSIDE FACE

MODEL: Default
 FILE NAME: p:\projects\trans\trans\pwr\hatched\Documents\projects_2018\CH401\401180022\03-WSP\CH401\62R23-RB-1-Sheets\CH401\62R23-sh-c\painted\all\USE\C22.dgn



WSP USA INC.
 30 N. LASALLE STREET
 SUITE 4200
 CHICAGO, IL 60602
 TEL: (312) 782-8150

USER NAME = USSJ696614	DESIGNED - TB/MHD	REVISED -
	DRAWN - TB/MDH	REVISED -
PLOT SCALE = 5/4,0000 '"/in.	CHECKED - LAS	REVISED -
PLOT DATE = 11/6/2025	DATE - 11/7/2025	REVISED -


STATE OF ILLINOIS
 DEPARTMENT OF TRANSPORTATION

DRAINAGE DETAILS – US 6 COMPENSATORY STORAGE STRUCTURE
 JUNCTION CHAMBER 2 – STA. 229+71 (2 OF 2)

SCALE: NONE SHEET 7 OF 11 SHEETS STA. 229+71 TO STA. 229+71

F.A.I. RTE.	SECTION	COUNTY	TOTAL SHEETS	SHEET NO.
80	FAI 80 21 STRUCTURE 2	WILL	1230	393
CONTRACT NO. 62R23				
ILLINOIS FED. AID PROJECT				


Model: Default
File Name: p:\projects\trans\scorp\ppl\hosted\Documents\projects_2018\CH401\401180022\03-WSP\CAD\62R23-RB-1-Sheets\CH401\62R23-shr-draintdetallUS6-UC31.dgn

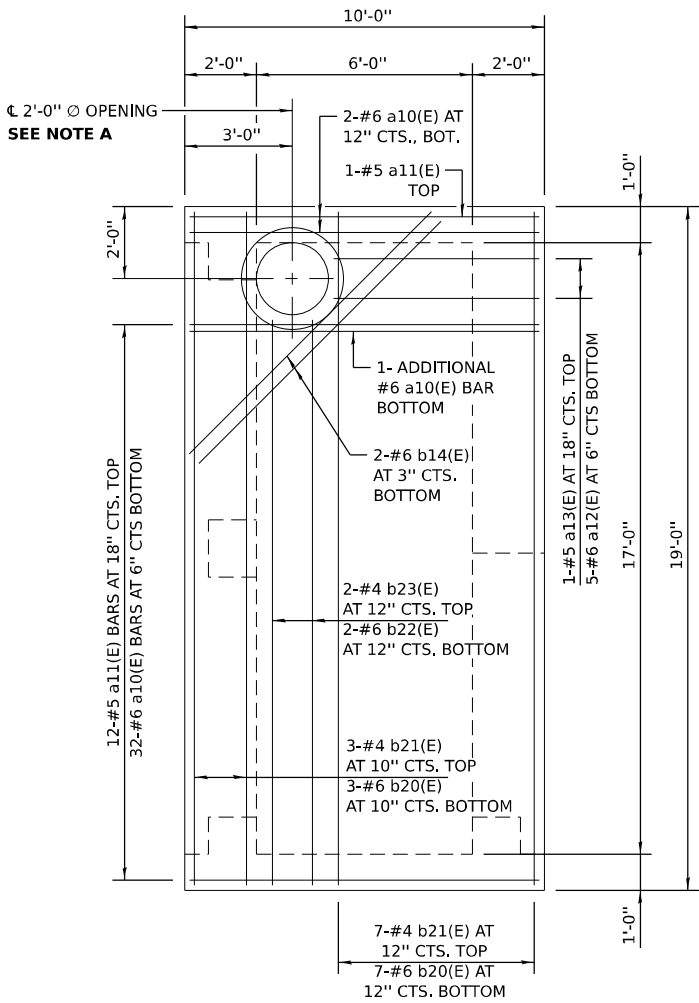


TOP SLAB PLAN

NOTE A


PROVIDE A 2'-11" $\varnothing$ 1" DEEP RECESS IN THE TOP SLAB, CENTERED OVER THE 2'-0" OPENING, FOR THE FRAME AND LID. FRAME SHALL BE SET ON AN INITIAL $\frac{3}{8}$ " MIN. GROUT BED (2:1 SAND AND PORTLAND CEMENT, VERY DRY MIX) TO MATCH RIM ELEVATION SHOWN ON DRAINAGE PLANS.

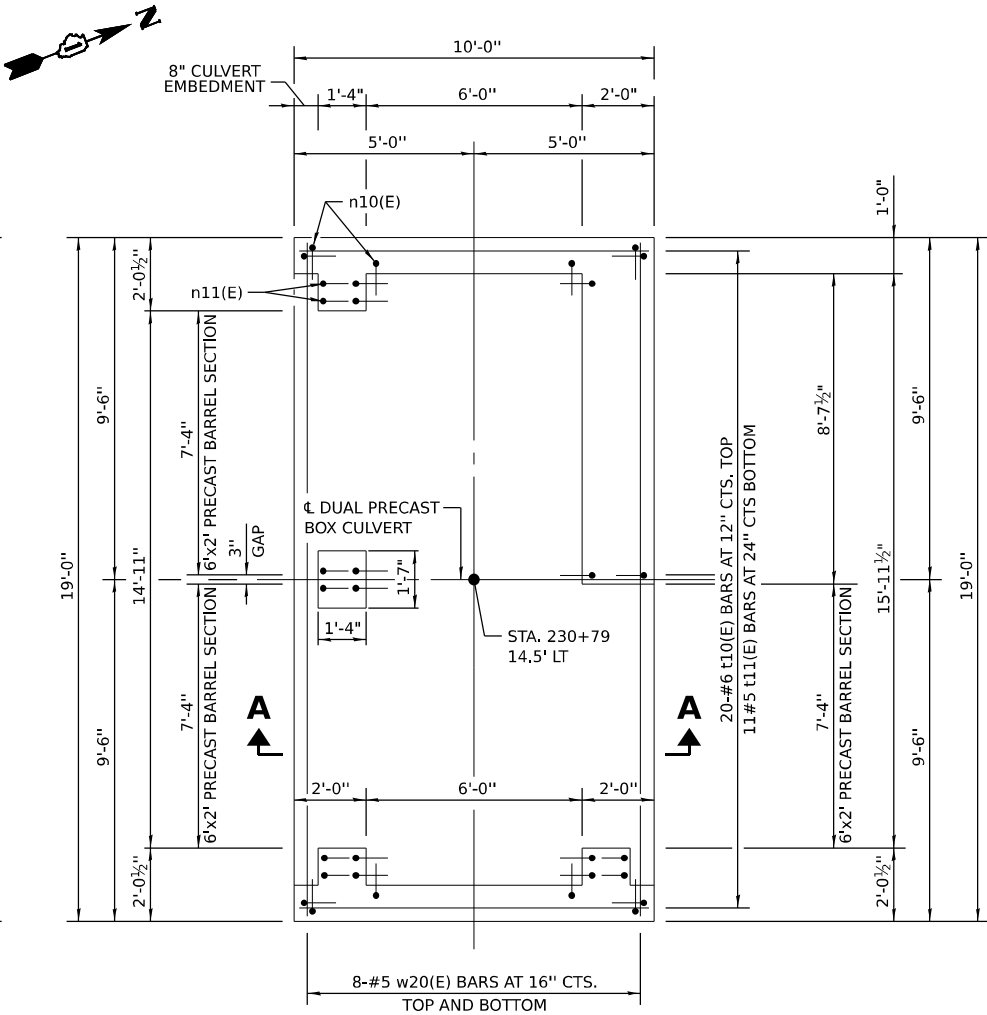

BOTTOM SLAB PLAN

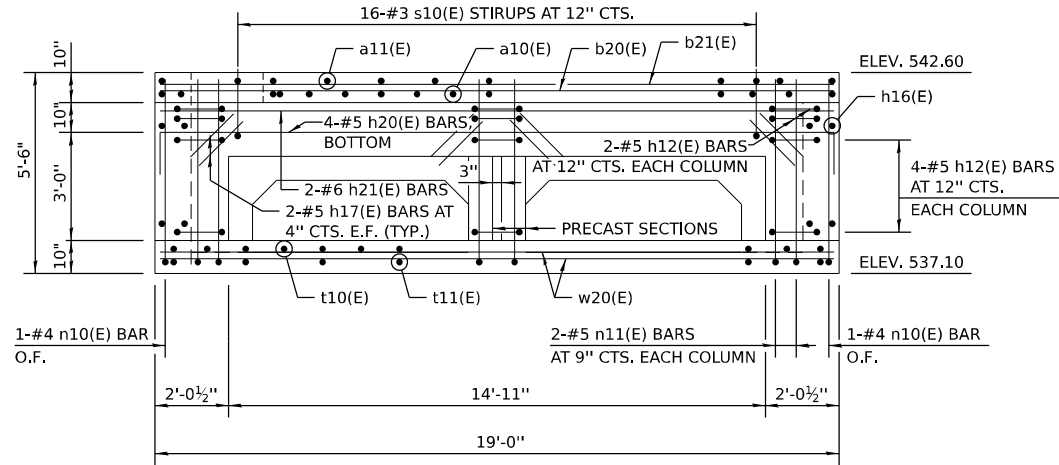

SOUTH WALL ELEVATION

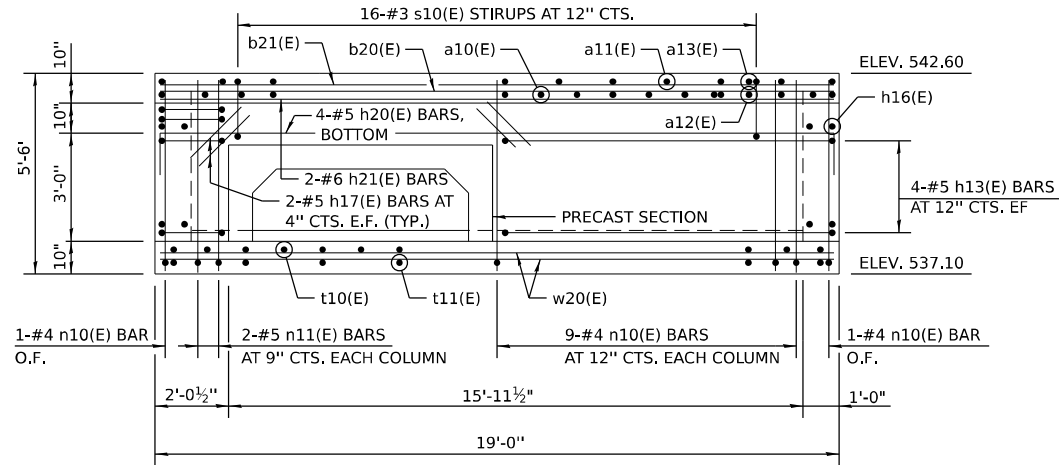

NORTH WALL ELEVATION

GENERAL NOTES

REINFORCEMENT BARS DESIGNATED (E) SHALL BE EPOXY COATED.

SEE SHEET 395 FOR SECTION A-A, ADDITIONAL ELEVATIONS AND DETAILS.

SEE SHEET 388 FOR SINGLE AND DUAL PRECAST BOX CULVERT DETAILS.

LEGEND

E.F. EACH FACE
I.F. INSIDE FACE
O.F. OUTSIDE FACE

STATE OF ILLINOIS
DEPARTMENT OF TRANSPORTATION

DRAINAGE DETAILS – US 6 COMPENSATORY STORAGE STRUCTURE
JUNCTION CHAMBER 3 – STA. 230+79 (1 OF 2)

SCALE: NONE SHEET 8 OF 11 SHEETS STA. 230+79 TO STA. 230+79


F.A.I. RTE.	SECTION	COUNTY	TOTAL SHEETS	SHEET NO.
80	FAI 80 21 STRUCTURE 2	WILL	1230	394
CONTRACT NO. 62R23				
ILLINOIS FED. AID PROJECT				




WSP USA INC.
30 N. LASALLE STREET
SUITE 4200
CHICAGO, IL 60602
TEL: (312) 782-8150

USER NAME	= USSJ696614	DESIGNED	- TB/MHD	REVISED	-
DRAWN	- TB/MHD	REVIS	-	REVIS	-
PLOT SCALE	= 5:4,0000 '"/in.	CHECKED	- LAS	REVIS	-
PLOT DATE	= 11/6/2025	DATE	- 11/7/2025	REVIS	-


Model: Default
File Name: p:\projects\trans\trans\corp\ppl-hosted\Documents\Projects_2018\CH4001401180022\03-WSP\CH4062\023-RB-1_Sheets\CH4062\023-RB-1.dgn
Model: Default
File Name: p:\projects\trans\trans\corp\ppl-hosted\Documents\Projects_2018\CH4001401180022\03-WSP\CH4062\023-RB-1_Sheets\CH4062\023-RB-1.dgn

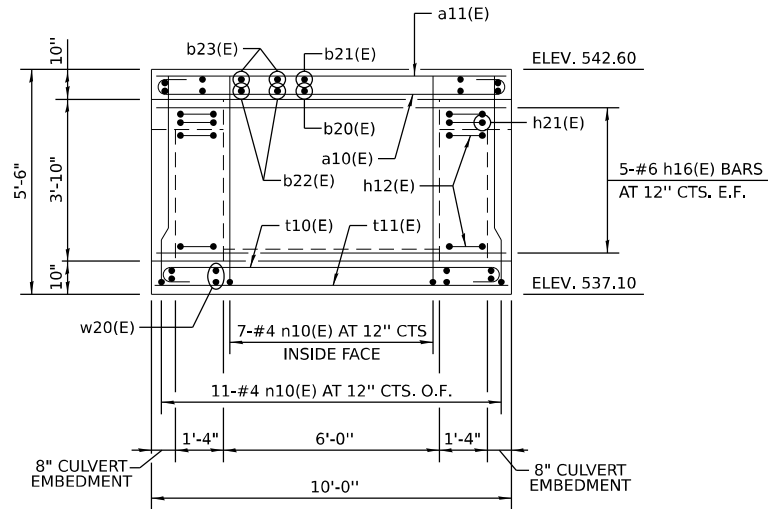

EAST WALL ELEVATION

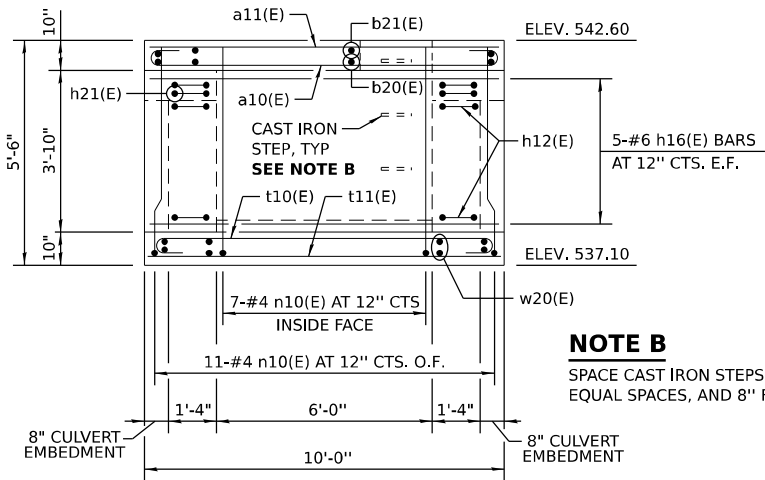


WEST WALL ELEVATION

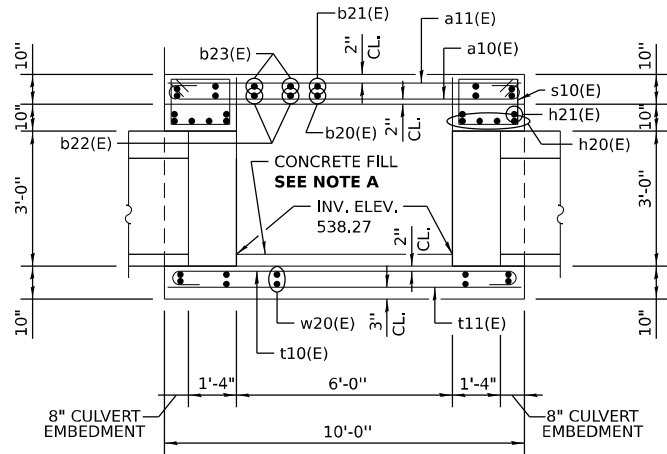

SECTION A-A

NOTE A

PLACE CONCRETE FILL AFTER INSTALLATION OF BOX CULVERT AND JUNCTION CHAMBER WALLS. MATCH TOP OF FILL ELEVATION TO BOX CULVERT INVERT ELEVATION 538.86.

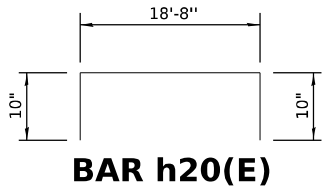

NOTE B

SPACE CAST IRON STEPS AT 12" TO 18", EQUAL SPACES, AND 8" FROM TOP OF SLAB.

BILL OF MATERIAL
(FOR INFORMATION ONLY)

BAR	NO.	SIZE	LENGTH	SHAPE
a10(E)	35	#6	11'-0"	
a11(E)	13	#5	9'-8"	
a12(E)	5	#6	7'-0"	
a13(E)	1	#5	5'-8"	
b14(E)	2	#6	9'-6"	
b20(E)	10	#6	18'-8"	
b21(E)	10	#4	18'-8"	
b22(E)	2	#6	15'-8"	
b23(E)	2	#4	15'-8"	
h12(E)	24	#5	5'-5"	
h13(E)	8	#5	9'-3"	
h16(E)	20	#6	9'-8"	
h17(E)	20	#5	2'-0"	
h20(E)	8	#5	20'-4"	
h21(E)	4	#6	18'-8"	
n10(E)	58	#4	5'-10"	
n11(E)	16	#5	6'-0"	
s10(E)	32	#3	6'-9"	
t10(E)	20	#6	11'-0"	
t11(E)	11	#5	9'-8"	
w20(E)	16	#5	18'-8"	
REINFORCEMENT BARS, EPOXY COATED			POUND	3260
CONCRETE STRUCTURES			CU YD	19.2
FRAMES AND LIDS, TYPE 1, OPEN LID			EACH	1
CAST IRON STEPS			EACH	3

GENERAL NOTES

REINFORCEMENT BARS DESIGNATED (E) SHALL BE EPOXY COATED.

SEE SHEET 391 FOR ADDITIONAL BAR BENDING DETAILS.

PROVIDE A 24" INSIDE DIA. CONCRETE ADJUSTING RING OF THE THICKNESS REQUIRED TO SET THE RIM TO THE ELEVATION SHOWN ON THE DRAINAGE PLANS. COST INCLUDED WITH THE JUNCTION CHAMBER PAY ITEM.

SEE SHEET 388 FOR SINGLE AND DUAL PRECAST BOX CULVERT DETAILS.

SEE STANDARD 602701 FOR DETAILS OF CAST IRON STEPS.

SEE STANDARD 604001 FOR DETAILS OF FRAME AND LID.

THE JUNCTION CHAMBER AT STATION 230+79 WILL BE PAID FOR AS JUNCTION CHAMBER NO. 3.

* INCLUDED IN THE COST OF JUNCTION CHAMBER NO. 3

LEGEND

E.F. EACH FACE
I.F. INSIDE FACE
O.F. OUTSIDE FACE

STATE OF ILLINOIS
DEPARTMENT OF TRANSPORTATION

DRAINAGE DETAILS – US 6 COMPENSATORY STORAGE STRUCTURE
JUNCTION CHAMBER 3 – STA. 230+79 (2 OF 2)


SCALE: NONE SHEET 9 OF 11 SHEETS STA. 230+79 TO STA. 230+79

F.A.I. RTE.	SECTION	COUNTY	TOTAL SHEETS	SHEET NO.
80	FAI 80 21 STRUCTURE 2	WILL	1230	395
CONTRACT NO. 62R23				
ILLINOIS FED. AID PROJECT				



WSP USA INC.
30 N. LASALLE STREET
SUITE 4200
CHICAGO, IL 60602
TEL: (312) 782-8150


USER NAME = USSJ696614	DESIGNED - TB/MHD	REVISED -
	DRAWN - TB/MHD	REVISED -
PLOT SCALE = 5:4,0000 '"/>	CHECKED - LAS	REVISED -
PLOT DATE = 11/6/2025	DATE - 11/7/2025	REVISED -

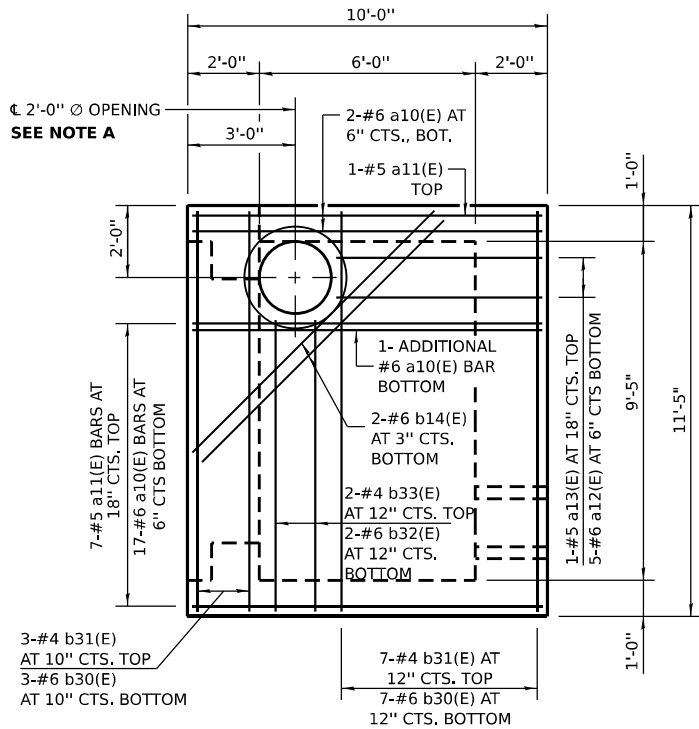


TOP SLAB PLAN

NOTE A


PROVIDE A 2'-11" $\varnothing$ 1" DEEP RECESS IN THE TOP SLAB, CENTERED OVER THE 2'-0" OPENING, FOR THE FRAME AND LID. FRAME SHALL BE SET ON AN INITIAL $\frac{3}{8}$ " MIN. GROUT BED (2:1 SAND AND PORTLAND CEMENT, VERY DRY MIX) TO MATCH RIM ELEVATION SHOWN ON DRAINAGE PLANS.

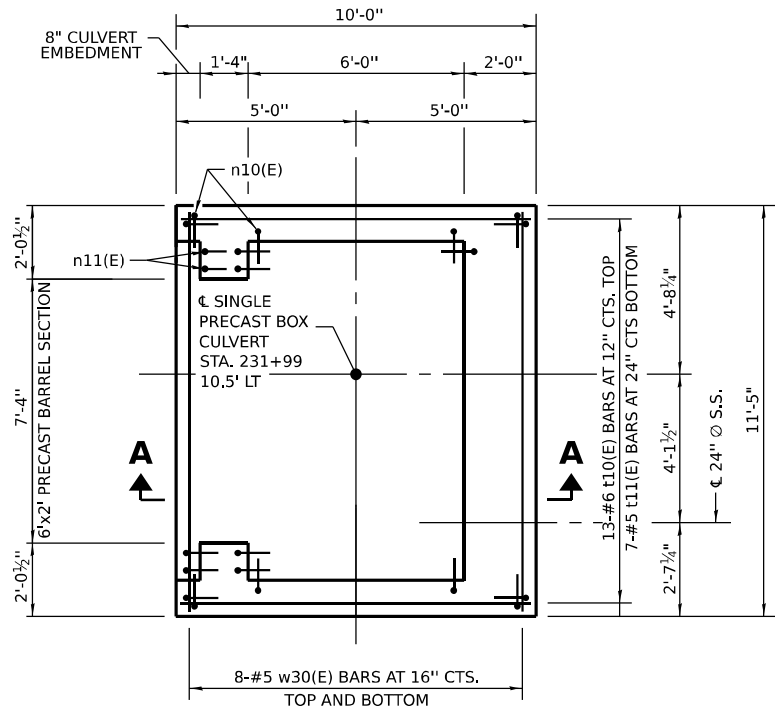

BOTTOM SLAB PLAN

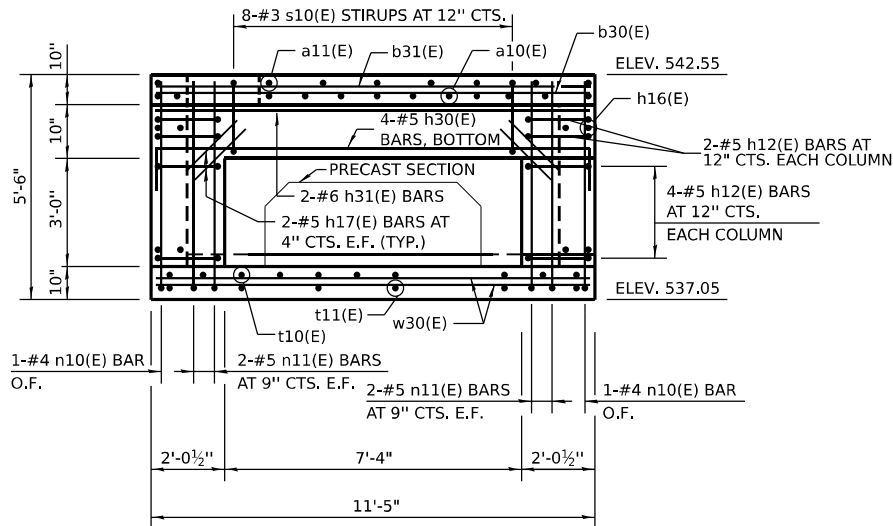

SOUTH WALL ELEVATION

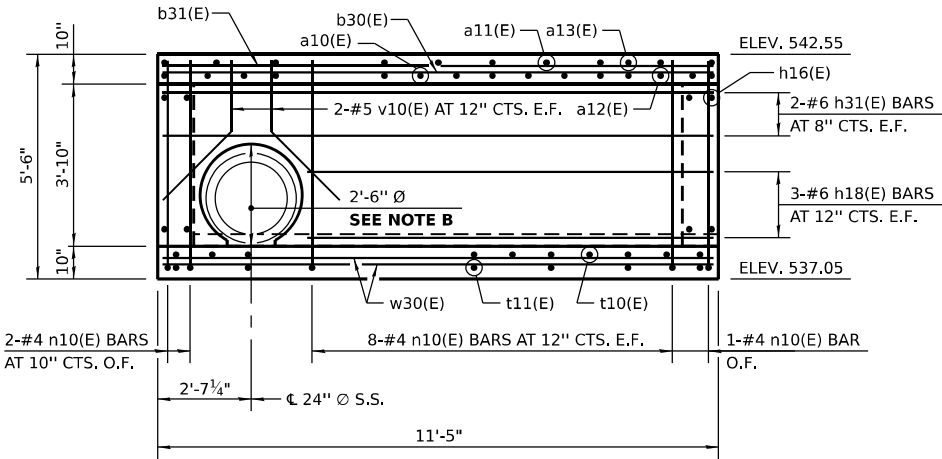

NORTH WALL ELEVATION

NOTE B

PROVIDE A 2'-10" $\varnothing$ FORMED HOLE IN THE WALL FOR THE 24" INSIDE DIA. STORM SEWER.

NOTES

REINFORCEMENT BARS DESIGNATED (E) SHALL BE EPOXY COATED.

SEE SHEET 397 FOR SECTIONS A-A AND B-B, ADDITIONAL ELEVATIONS AND DETAILS.

SEE SHEET 388 FOR SINGLE PRECAST BOX CULVERT DETAILS.

LEGEND

E.F. EACH FACE
I.F. INSIDE FACE
O.F. OUTSIDE FACE

Model: Default
File Name: p:\projects\trans\trans\corp\ppl\hosted\Documents\Projects_2018\CH4001401180022\03-WSP\CAD\62R23-RB-1_Sheets\Civil\62R23-shr-draindetail\US6-JC41.dgn



WSP USA Inc.
30 N. LA SALLE STREET
SUITE 4200
CHICAGO, IL 60602
TEL: (312) 782-8150

USER NAME	= USSJ696614	DESIGNED -	TB/MHD	REVISED -	
DRAWN -	TB/MHD	REVISED -			
PLOT SCALE	= 5:4,0000 " = 1 / in.	CHECKED -	LAS	REVISED -	
PLOT DATE	= 11/6/2025	DATE	= 11/7/2025	REVISED -	

STATE OF ILLINOIS
DEPARTMENT OF TRANSPORTATION

DRAINAGE DETAILS – US 6 COMPENSATORY STORAGE STRUCTURE
JUNCTION CHAMBER 4 – STA. 231+99 (1 OF 2)

SCALE: NONE SHEET 10 OF 11 SHEETS STA. 231+99 TO STA. 231+99


F.A.I. RTE.	SECTION	COUNTY	TOTAL SHEETS	SHEET NO.
80	FAI 80 21 STRUCTURE 2	WILL	1230	396
CONTRACT NO. 62R23				
		ILLINOIS	FED. AID PROJECT	

BILL OF MATERIAL
(FOR INFORMATION ONLY)


BAR	NO.	SIZE	LENGTH	SHAPE
a10(E)	20	#6	11'-0"	
a11(E)	8	#5	9'-8"	
a12(E)	5	#6	7'-0"	
a13(E)	1	#5	5'-8"	
b14(E)	2	#6	9'-6"	
b30(E)	10	#6	11'-1"	
b31(E)	10	#4	11'-1"	
b32(E)	2	#6	8'-1"	
b33(E)	2	#4	8'-1"	
h12(E)	12	#5	5'-5"	
h16(E)	20	#6	9'-8"	
h17(E)	4	#5	2'-0"	
h18(E)	6	#6	7'-1"	
h30(E)	4	#5	12'-9"	
h31(E)	6	#6	11'-1"	
n10(E)	57	#4	5'-10"	
n11(E)	8	#5	6'-0"	
s10(E)	8	#3	6'-9"	
t10(E)	13	#6	11'-0"	
t11(E)	7	#5	9'-8"	
v10(E)	4	#5	3'-9"	
w30(E)	16	#5	11'-1"	
* REINFORCEMENT BARS, EPOXY COATED			POUND	2140
* CONCRETE STRUCTURES			CU YD	10.7
* FRAMES AND LIDS, TYPE 1, OPEN LID			EACH	1
* CAST IRON STEPS			EACH	3

NOTES

- REINFORCEMENT BARS DESIGNATED (E) SHALL BE EPOXY COATED.
- SEE SHEET 391 FOR ADDITIONAL BAR BENDING DETAILS.
- PROVIDE A 24" INSIDE DIA. CONCRETE ADJUSTING RING OF THE THICKNESS REQUIRED TO SET THE RIM TO THE ELEVATION SHOWN ON THE DRAINAGE PLANS. COST INCLUDED WITH THE JUNCTION CHAMBER PAY ITEM.
- SEE SHEET 388 FOR SINGLE PRECAST BOX CULVERT DETAILS.
- SEE STANDARD 602701 FOR DETAILS OF CAST IRON STEPS.
- SEE STANDARD 604001 FOR DETAILS OF FRAME AND LID.
- THE JUNCTION CHAMBER AT STATION 231+99 WILL BE PAID FOR AS JUNCTION CHAMBER NO. 4.
- * INCLUDED IN THE COST OF JUNCTION CHAMBER NO. 4.

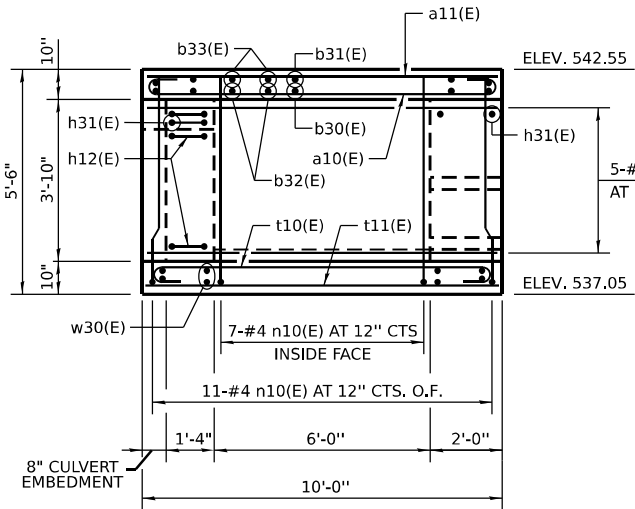


EAST WALL ELEVATION

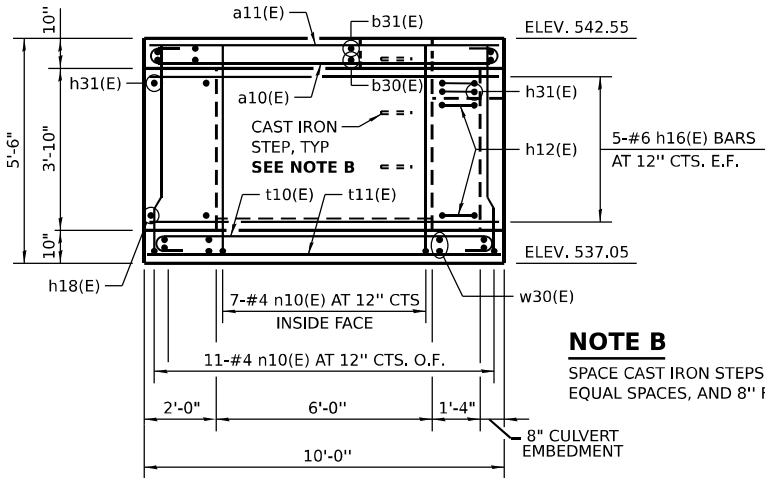


WEST WALL ELEVATION



BAR h30(E)

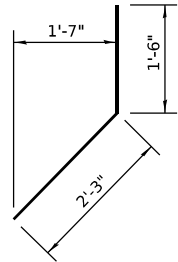

BAR v10(E)

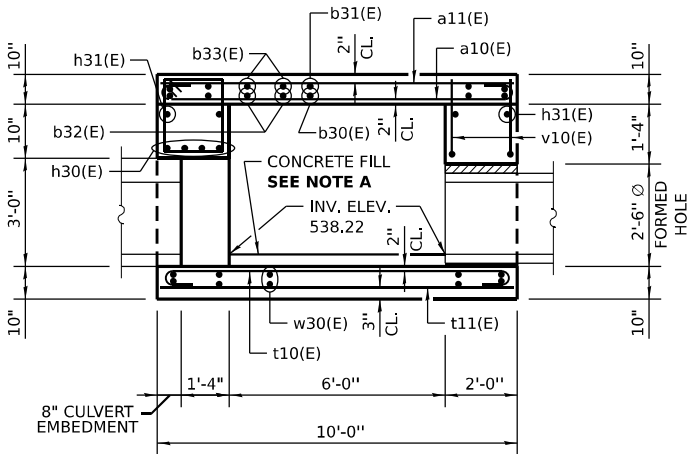

SECTION A-A

NOTE A

PLACE CONCRETE FILL AFTER INSTALLATION OF BOX CULVERT AND JUNCTION CHAMBER WALLS. MATCH TOP OF FILL ELEVATION TO BOX CULVERT INVERT ELEVATION 538.81.

LEGEND

- E.F. EACH FACE
I.F. INSIDE FACE
O.F. OUTSIDE FACE

Model: Default
File Name: p:\projects\trans\transcorp\ppl\hosted\Documents\projects_2018\CH401\401180022\03-WSP\CD\626203-RB-1-Sheets\CD\102R23-shr-d\painted\all\USE-C42.dgn



WSP USA INC.
30 N. LA SALLE STREET
SUITE 4200
CHICAGO, IL 60602
TEL: (312) 782-8150

USER NAME	= USSJ696614
DESIGNED	- TB/MHD
DRAWN	- TB/MHD
CHECKED	- LAS
DATE	- 11/7/2025
PLOT SCALE	= 5:4,0000 '"/ in.
PLOT DATE	= 11/6/2025

DESIGNED	- TB/MHD
REVIS	-
DRAWN	- TB/MHD
REVIS	-
CHECKED	- LAS
REVIS	-
DATE	- 11/7/2025
REVIS	-





STATE OF ILLINOIS
DEPARTMENT OF TRANSPORTATION

DRAINAGE DETAILS – US 6 COMPENSATORY STORAGE STRUCTURE
JUNCTION CHAMBER 4 – STA. 231+99 (2 OF 2)

SCALE: NONE SHEET 11 OF 11 SHEETS STA. 231+99 TO STA. 231+99

F.A.I. RTE.	SECTION	COUNTY	TOTAL SHEETS	SHEET NO.
80	FAI 80 21 STRUCTURE 2	WILL	1230	397
CONTRACT NO. 62R23				
ILLINOIS FED. AID PROJECT				

Model: Default
File Name: p:\projects\trans\transcorp\p1\hatched\Documents\Projects_2018\C4001401180022\03-V597\project_info\Utilities\COU-V2-Utilities\62R23-4B-1\Sheet-D 62R23-sh-detail3.dgn
2018/C4001401180022\03-V597\project_info\Utilities\COU-V2-Utilities\62R23-4B-1\Sheet-D 62R23-sh-detail3.dgn

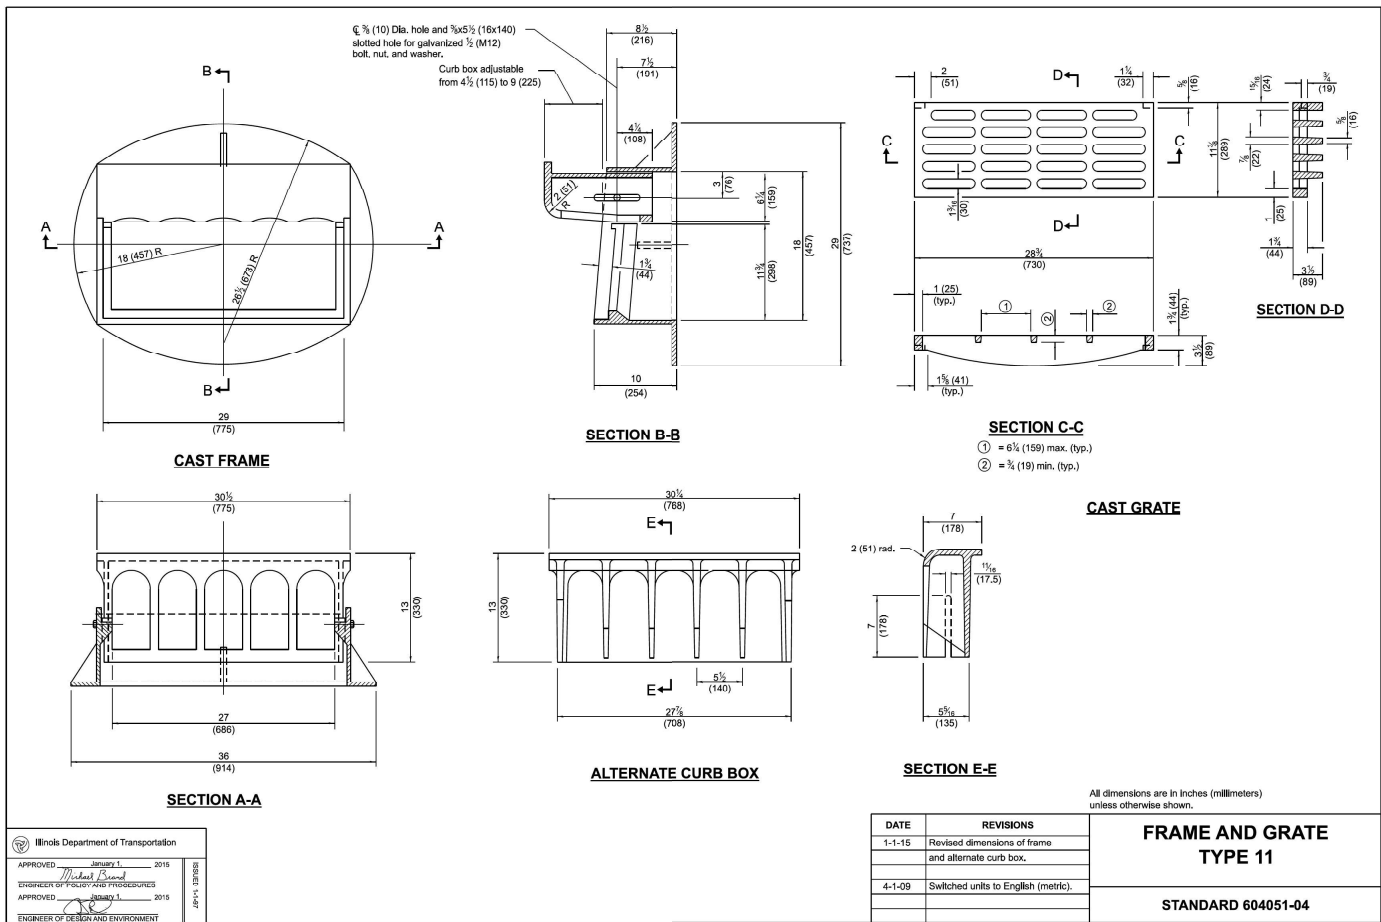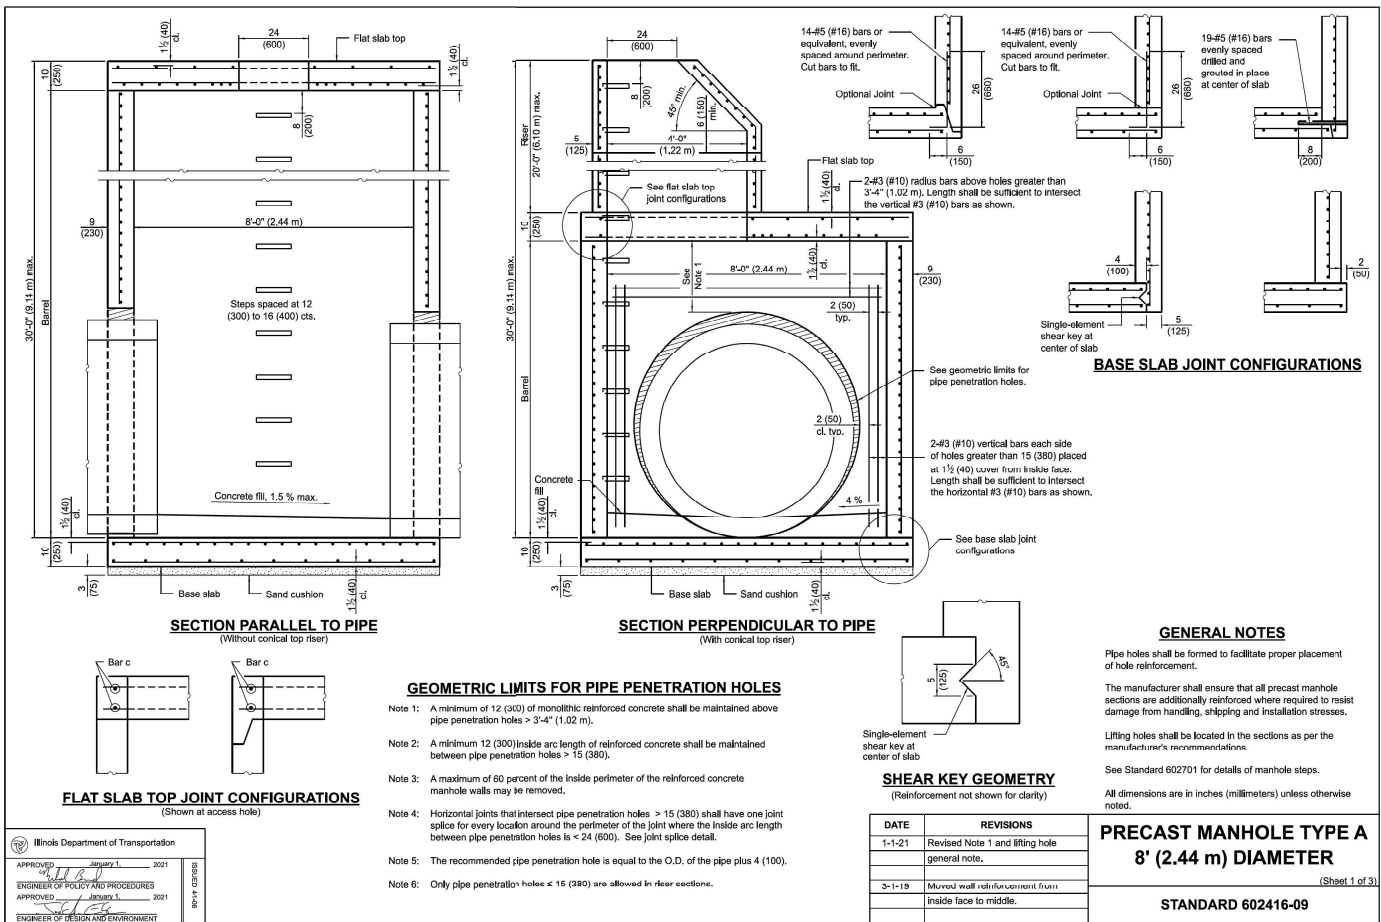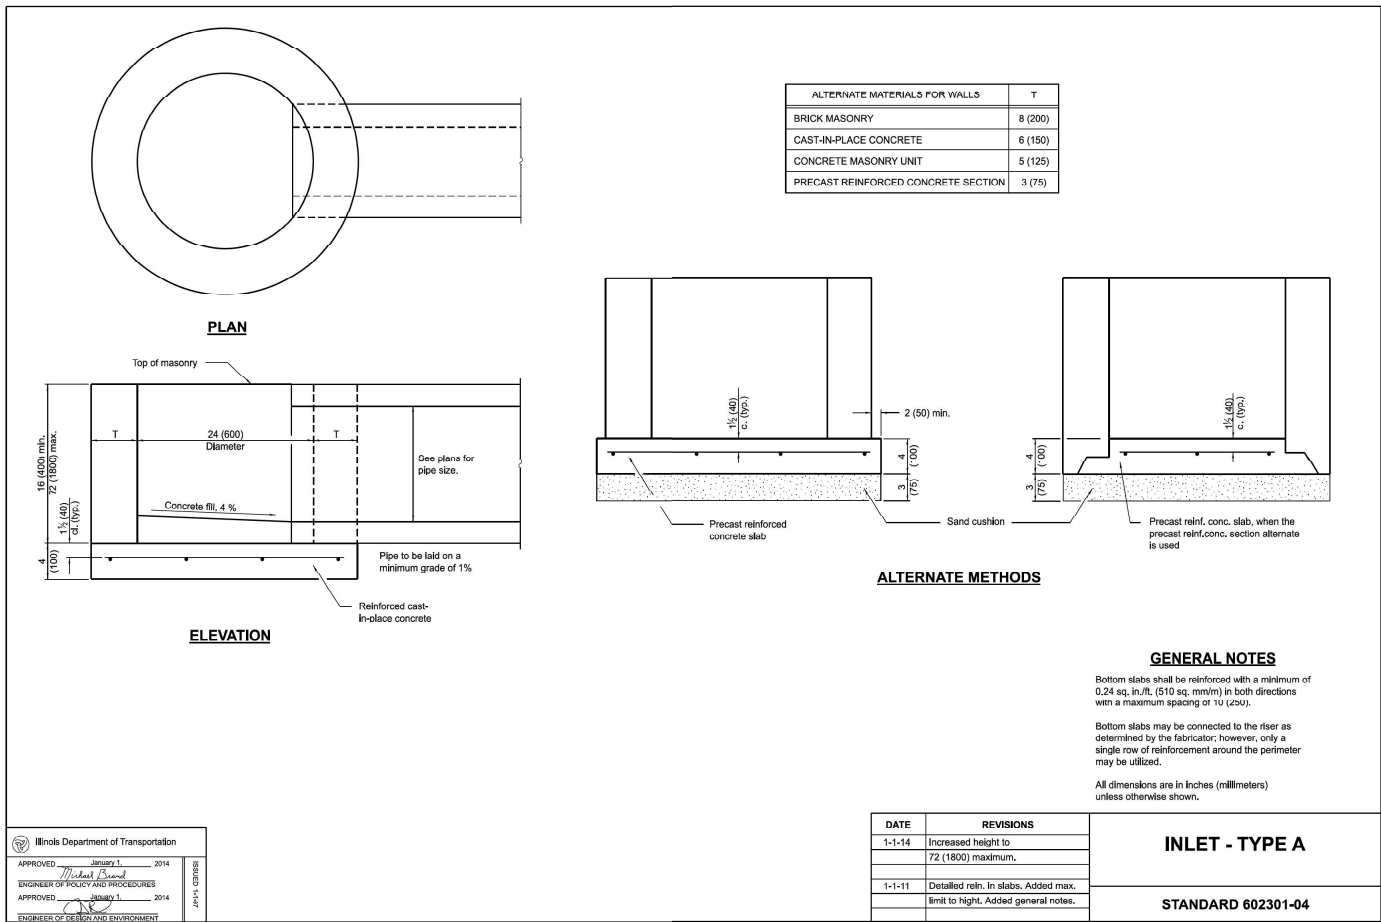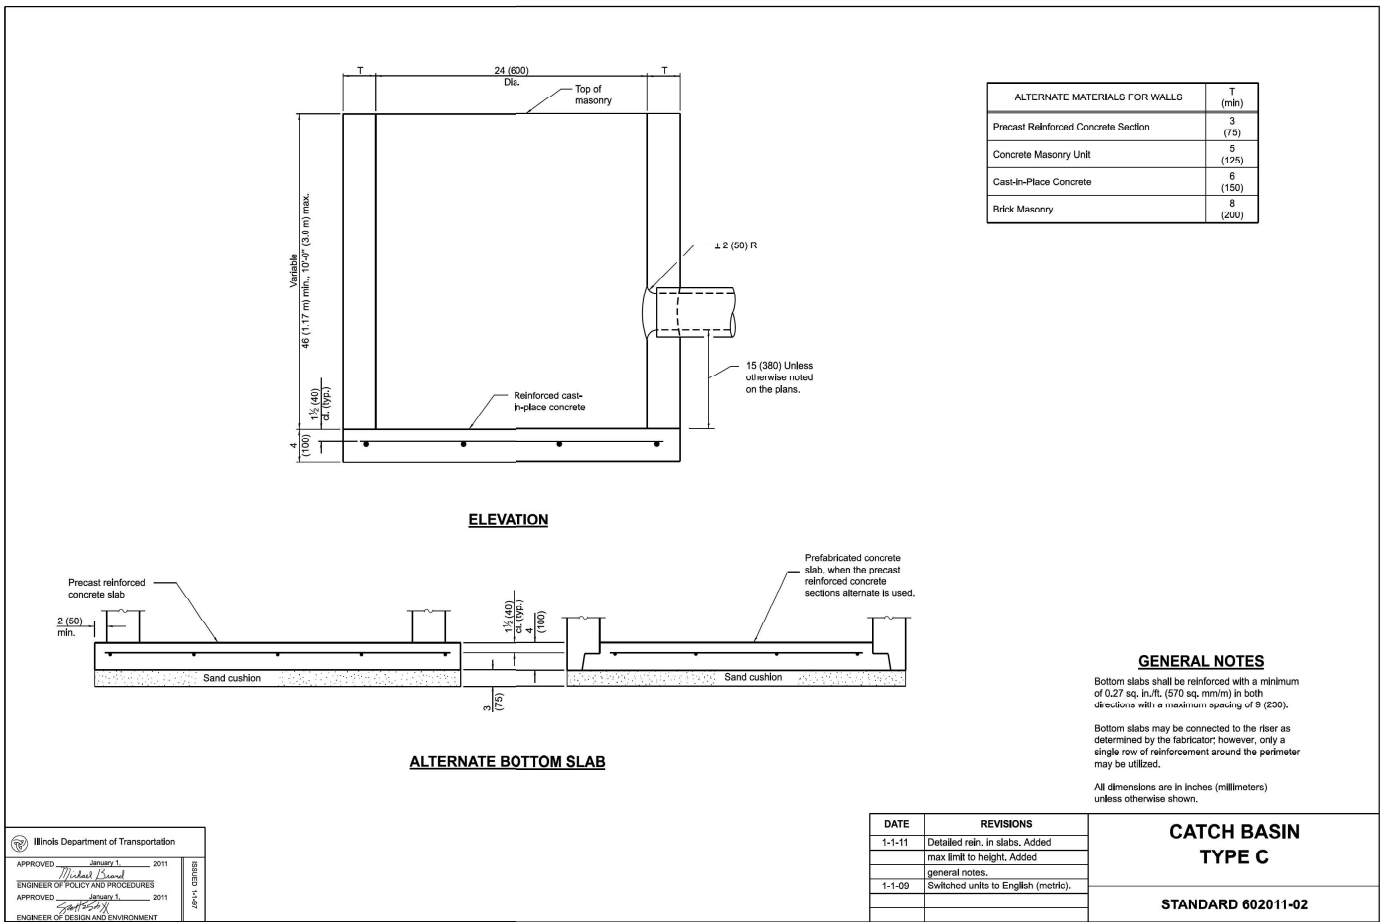

V3 Companies
7325 Janes Avenue
Woodridge, IL 60517
630.724.9200 phone
630.724.9202 fax
www.v3co.com

USER NAME = dpung
PLOT SCALE =
PLOT DATE = 11/5/2025

DESIGNED - CD
DRAWN - DP
CHECKED - JH
DATE - 11/7/2025

REVISED -
REVISED -
REVISED -
REVISED -

STATE OF ILLINOIS
DEPARTMENT OF TRANSPORTATION

JOLIET DRAINAGE DETAILS

SCALE: NONE SHEET 3 OF 3 SHEETS STA. TO STA.

F.A.I. RTE.	SECTION	COUNTY	TOTAL SHEETS	SHEET NO.
80	FAI 80 21 STRUCTURE 2	WILL	1230	400
CONTRACT NO. 62R23				
ILLINOIS		FED. AID PROJECT		