


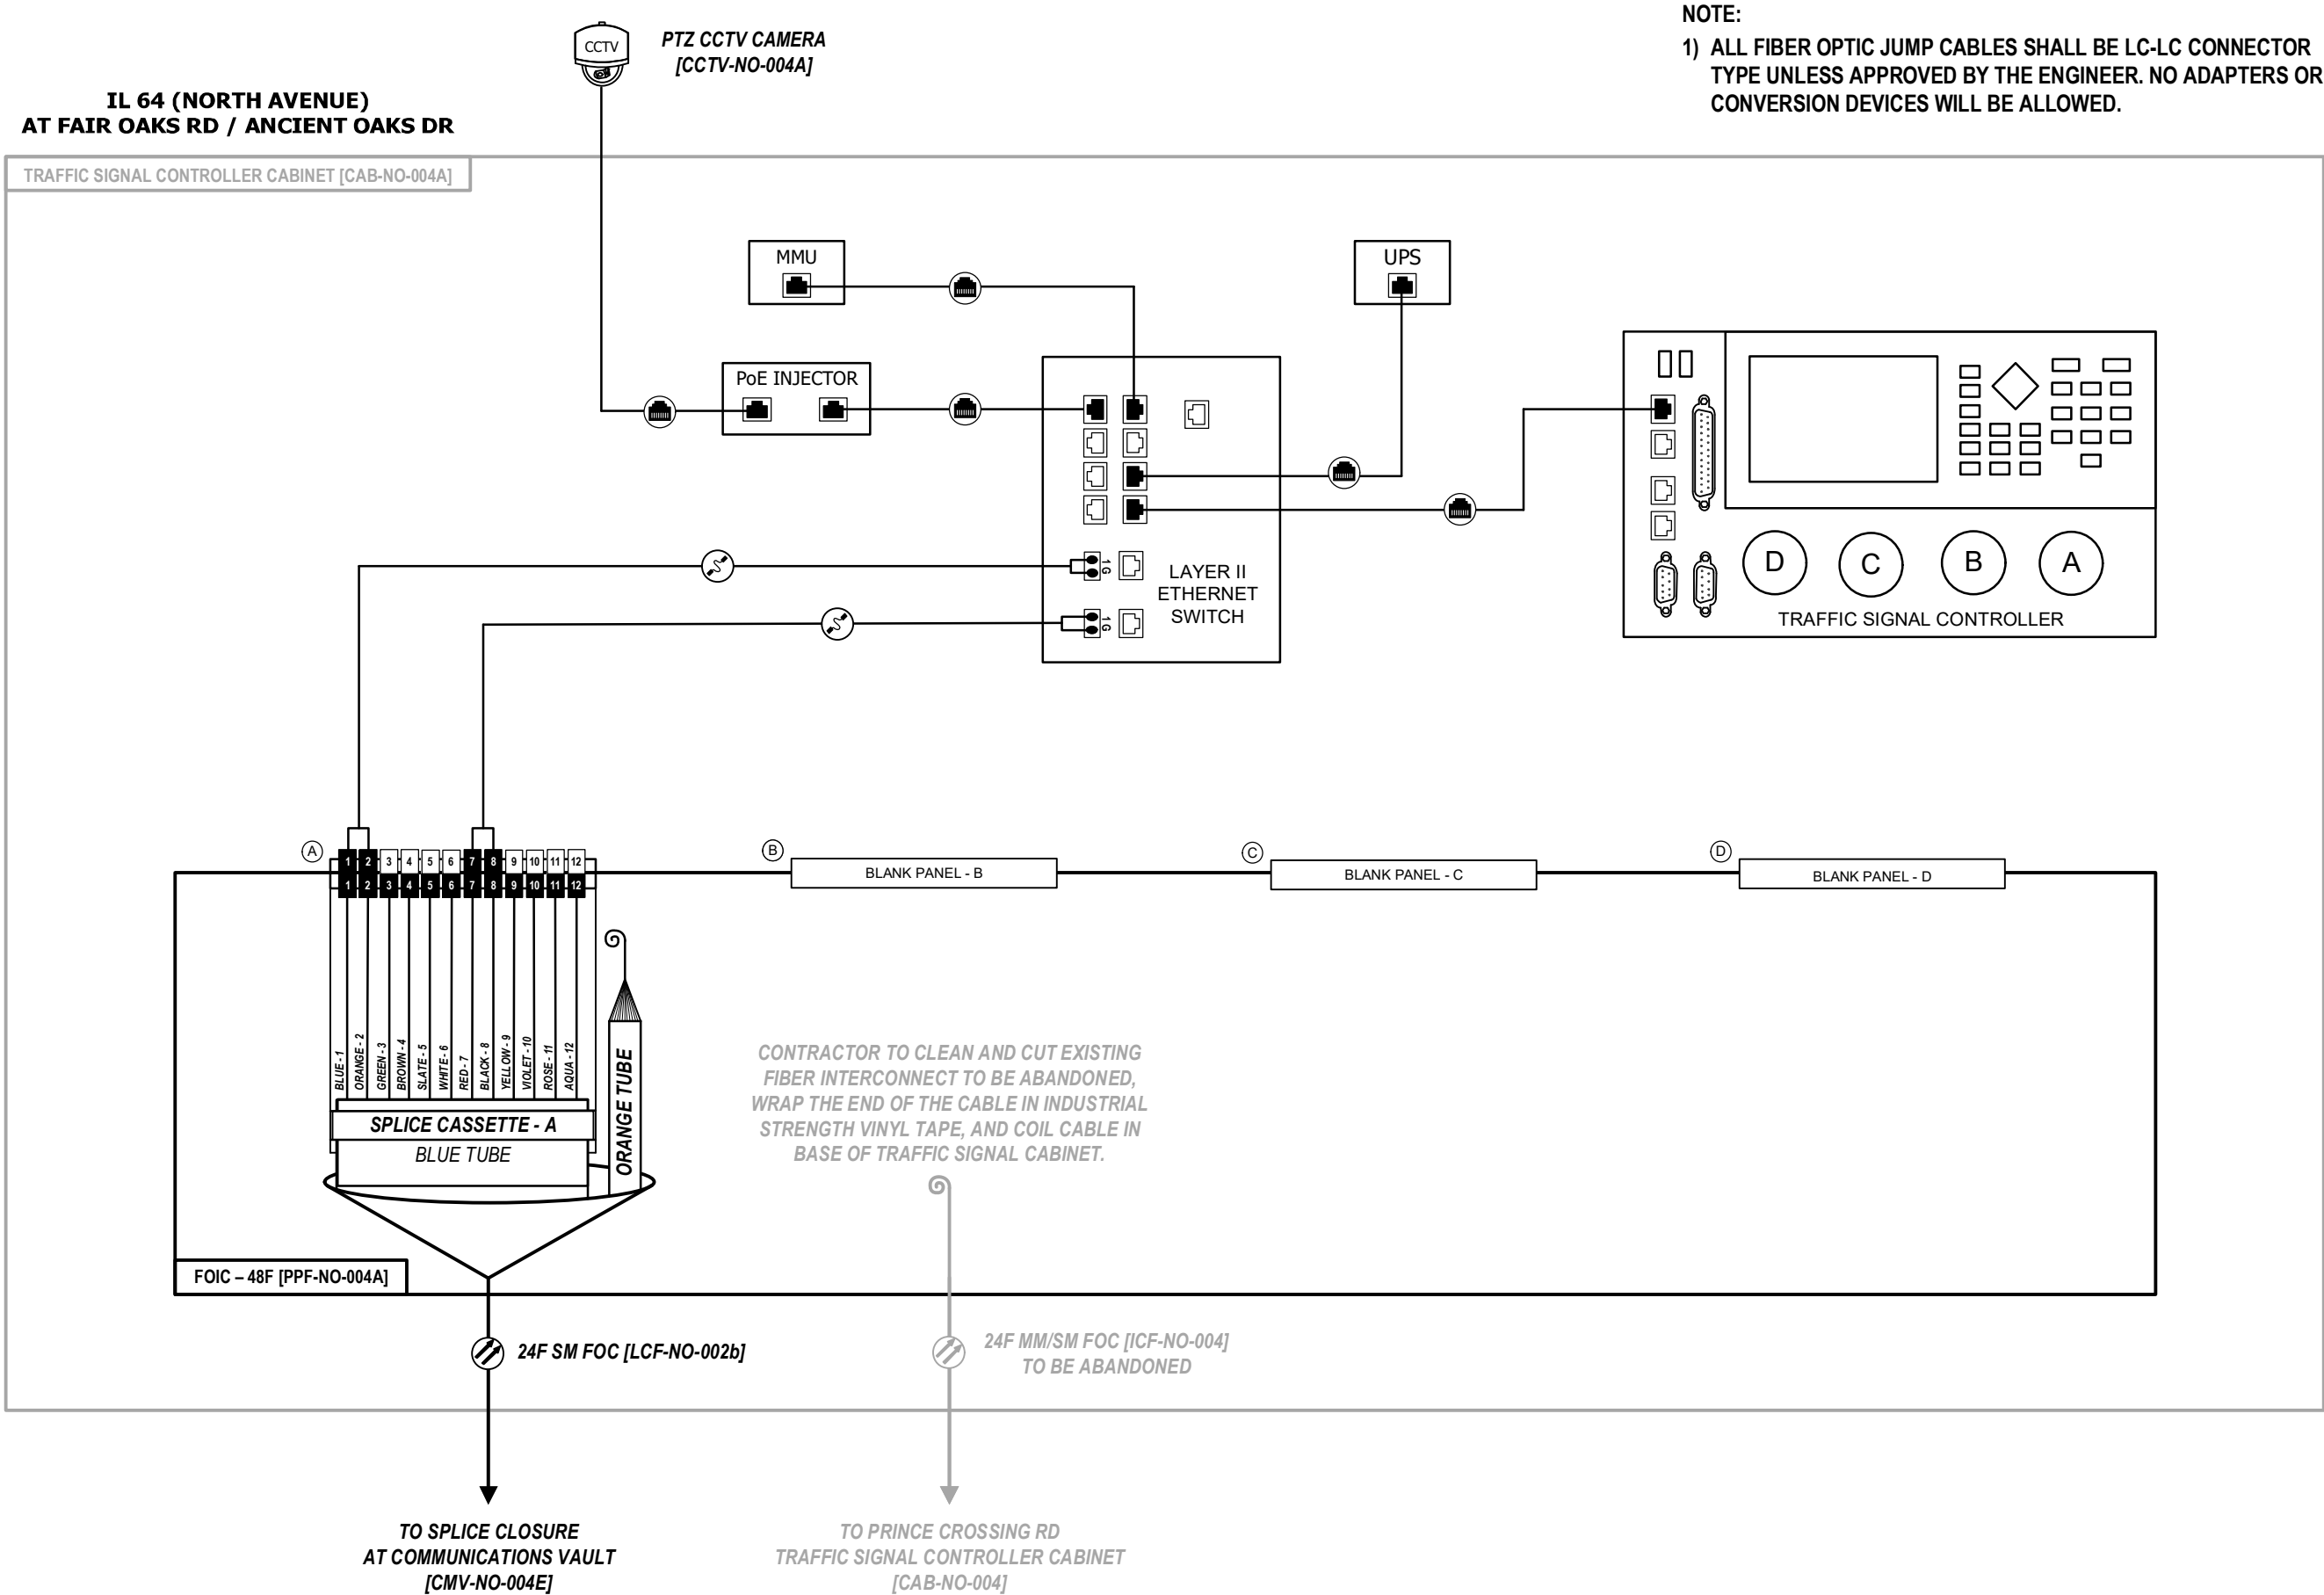

D:\08121-sht-comm-viso

Kimley»Horn


USER NAME =	DESIGNED -	REVISED -
	DRAWN -	REVISED -
PLOT SCALE = N.T.S.	CHECKED -	REVISED -
PLOT DATE =	DATE -	REVISED -

STATE OF ILLINOIS
DEPARTMENT OF TRANSPORTATION

FIBER SPLICING AND CABINET CONNECTION DETAILS
TRAFFIC SIGNAL CONTROLLER CABINET [CAB-NO-004A]

SCALE:	SHEET	OF	SHEETS	STA.	TO STA.
--------	-------	----	--------	------	---------

F.A.P. RTE.	SECTION	COUNTY	TOTAL SHEETS	SHEET NO.
307	2020-263-SUR,SW&TS	DUPAGE	529	401
CONTRACT NO. 62N33				
ILLINOIS				

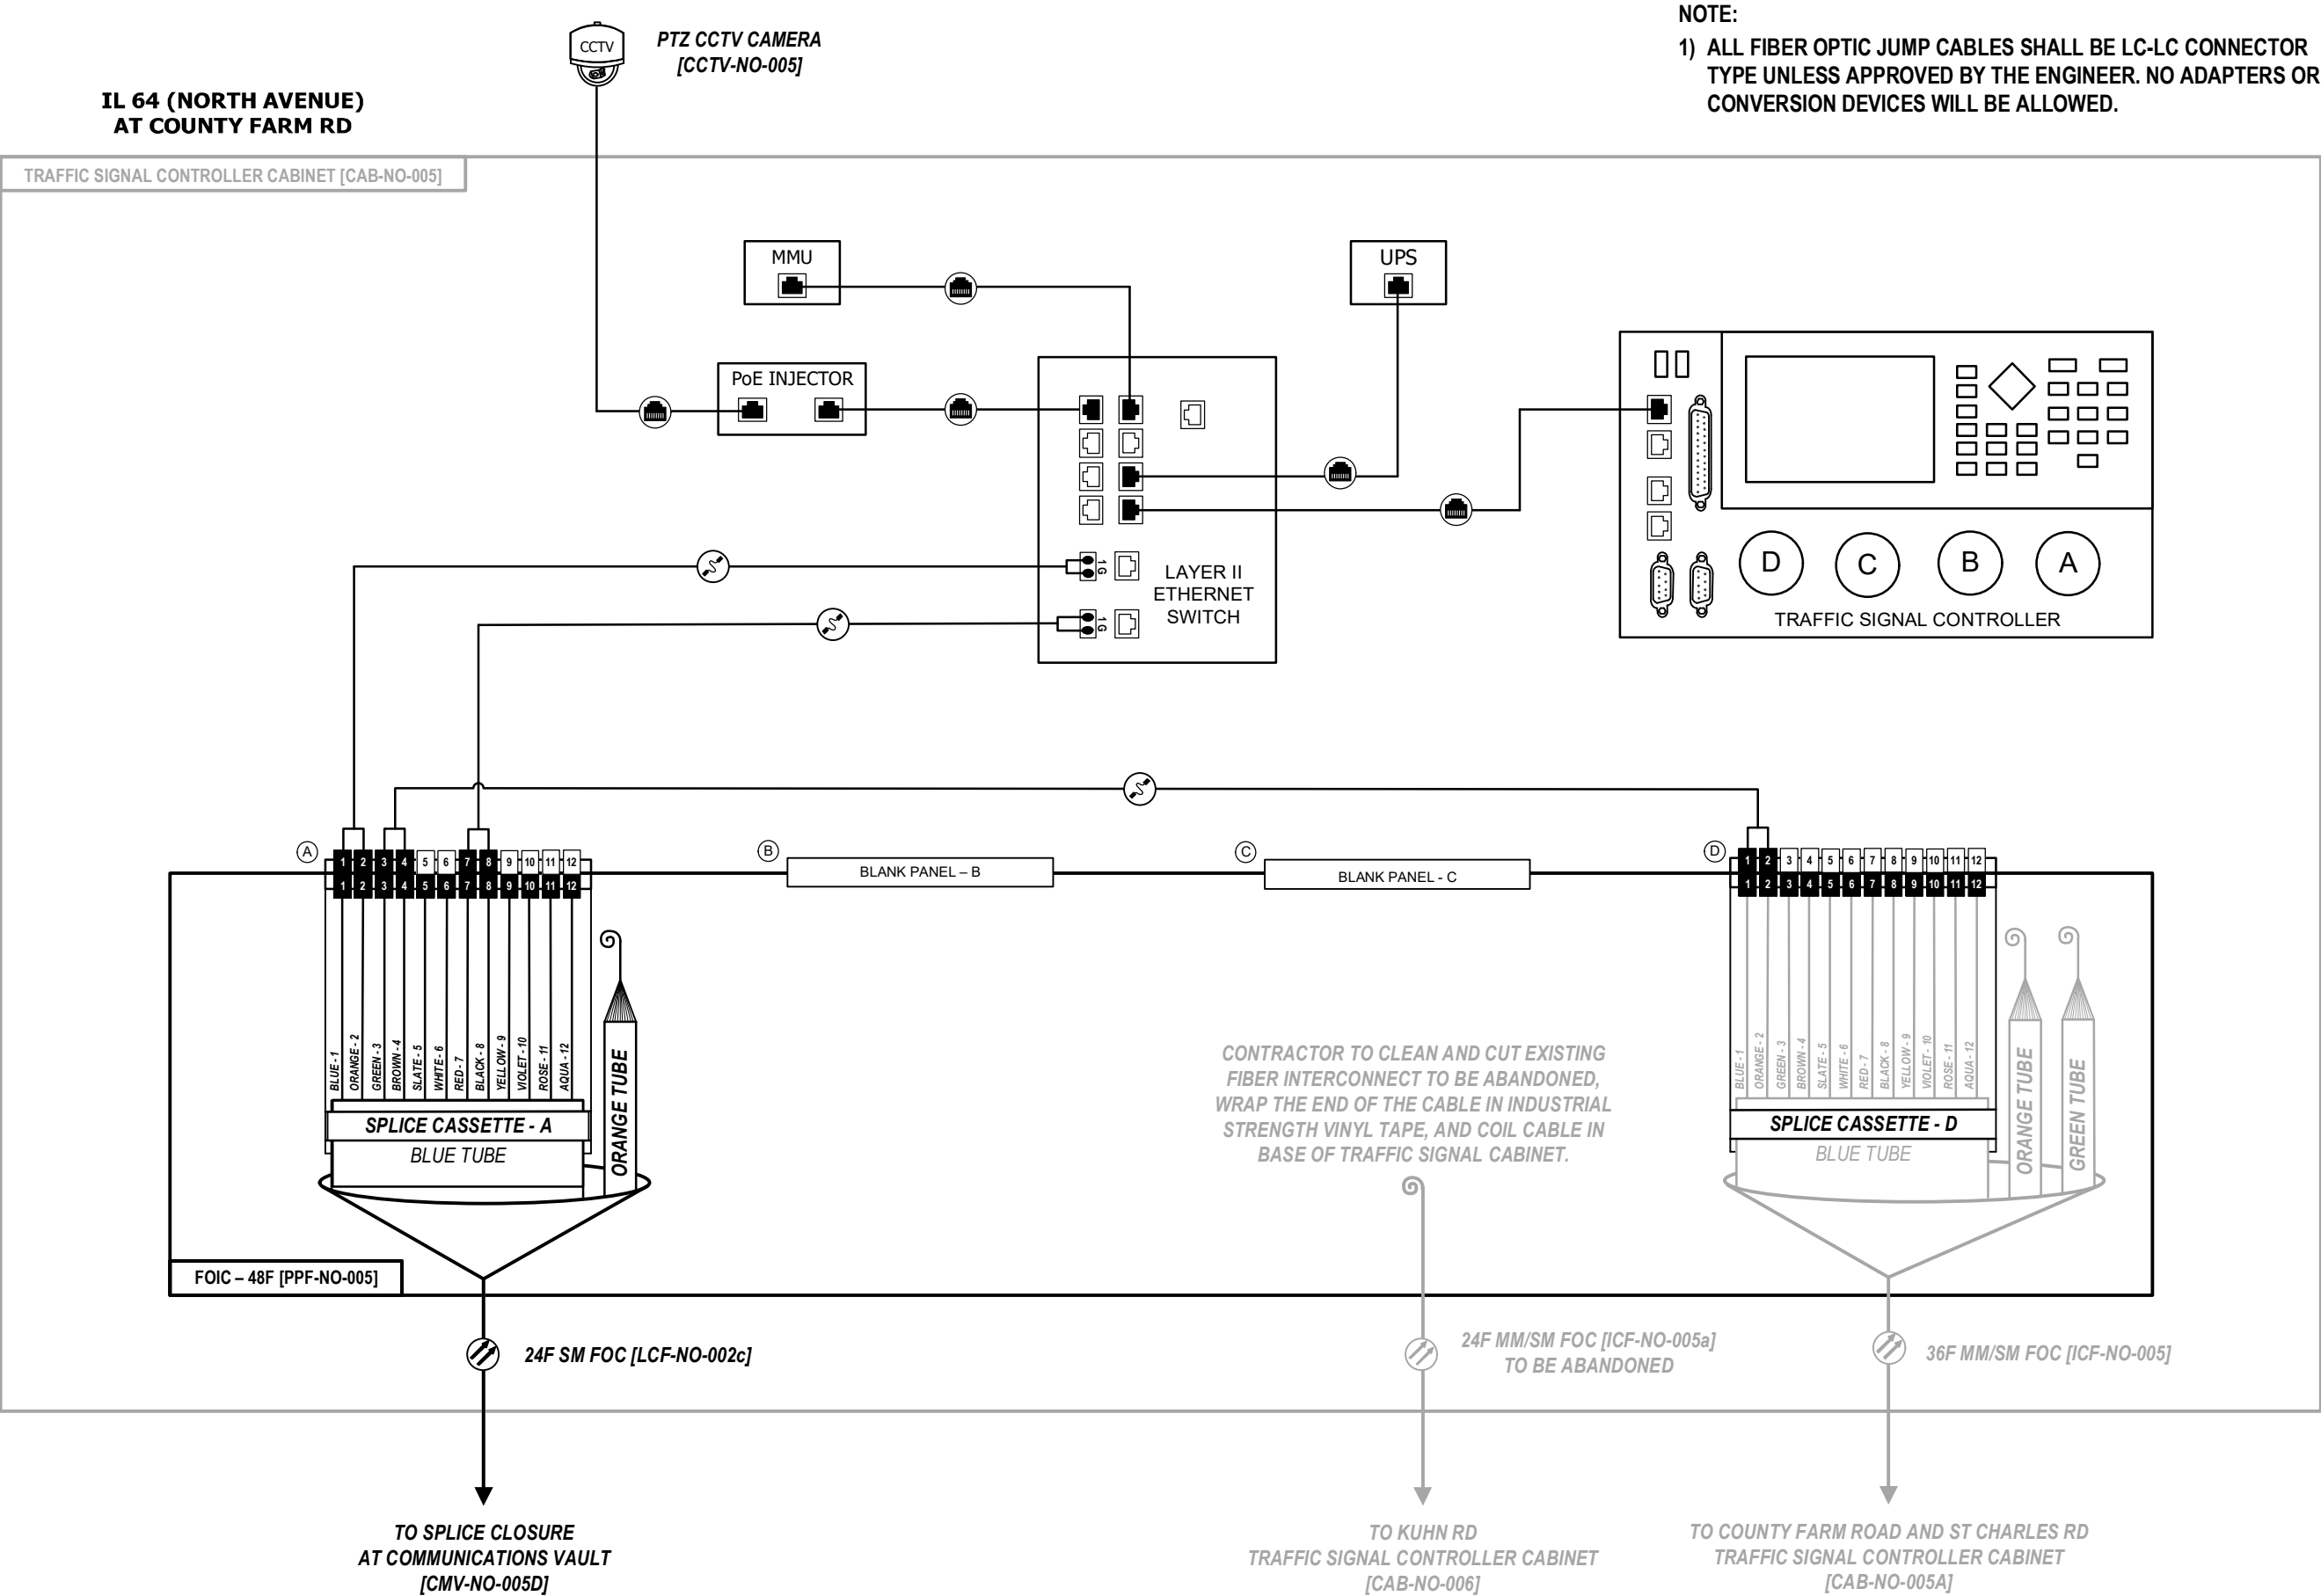

D:\08121-sht-comm-viso

Kimley»Horn


USER NAME =	DESIGNED -	REVISED -
	DRAWN -	REVISED -
PLOT SCALE = N.T.S.	CHECKED -	REVISED -
PLOT DATE =	DATE -	REVISED -

STATE OF ILLINOIS
DEPARTMENT OF TRANSPORTATION

FIBER SPLICING AND CABINET CONNECTION DETAILS
TRAFFIC SIGNAL CONTROLLER CABINET [CAB-NO-005]

SCALE: SHEET OF SHEETS STA. TO STA.

F.A.P. RTE.	SECTION	COUNTY	TOTAL SHEETS	SHEET NO.
307	2020-263-SUR,SW&TS	DUPAGE	529	402
CONTRACT NO. 62N33				
ILLINOIS FED. AID PROJECT				

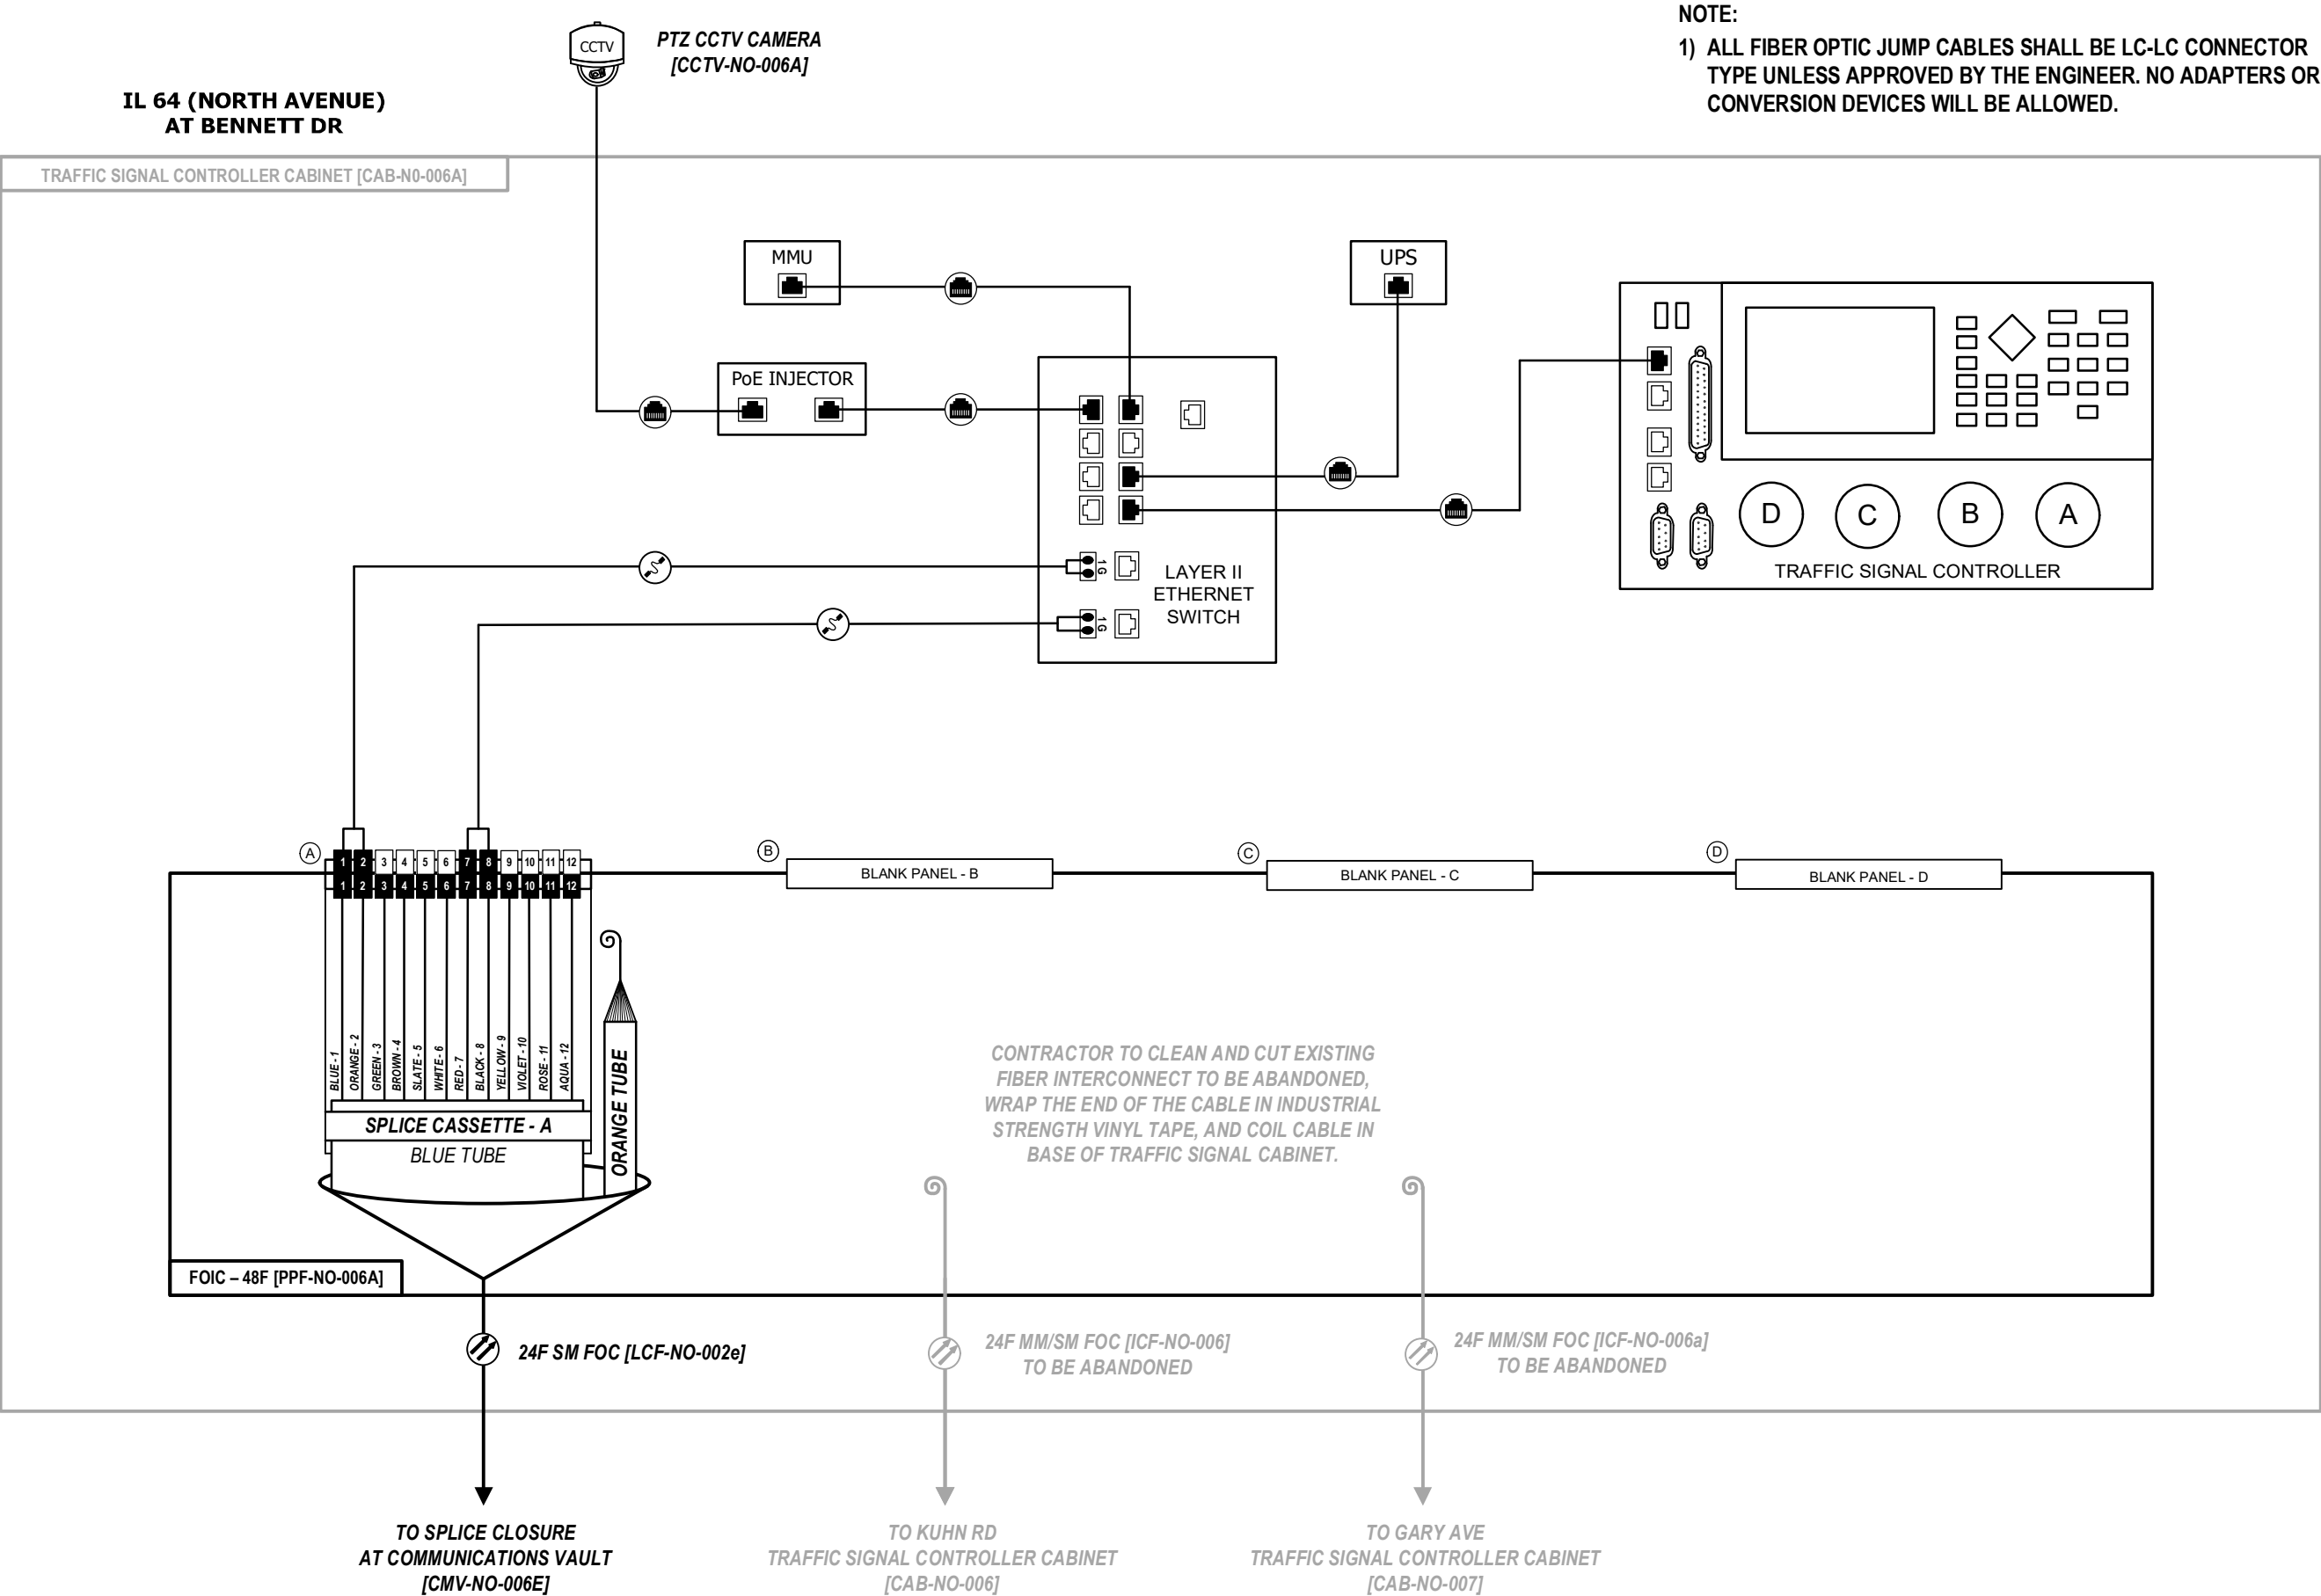

D:\08121-sht-comm-viso

Kimley»Horn


USER NAME =	DESIGNED -	REVISED -
	DRAWN -	REVISED -
PLOT SCALE = N.T.S.	CHECKED -	REVISED -
PLOT DATE =	DATE -	REVISED -

STATE OF ILLINOIS
DEPARTMENT OF TRANSPORTATION

FIBER SPLICING AND CABINET CONNECTION DETAILS
TRAFFIC SIGNAL CONTROLLER CABINET [CAB-NO-006A]

SCALE: SHEET OF SHEETS STA. TO STA.

F.A.P. RTE.	SECTION	COUNTY	TOTAL SHEETS	SHEET NO.
307	2020-263-SUR,SW&TS	DUPAGE	529	404
CONTRACT NO. 62N33				
ILLINOIS FED. AID PROJECT				

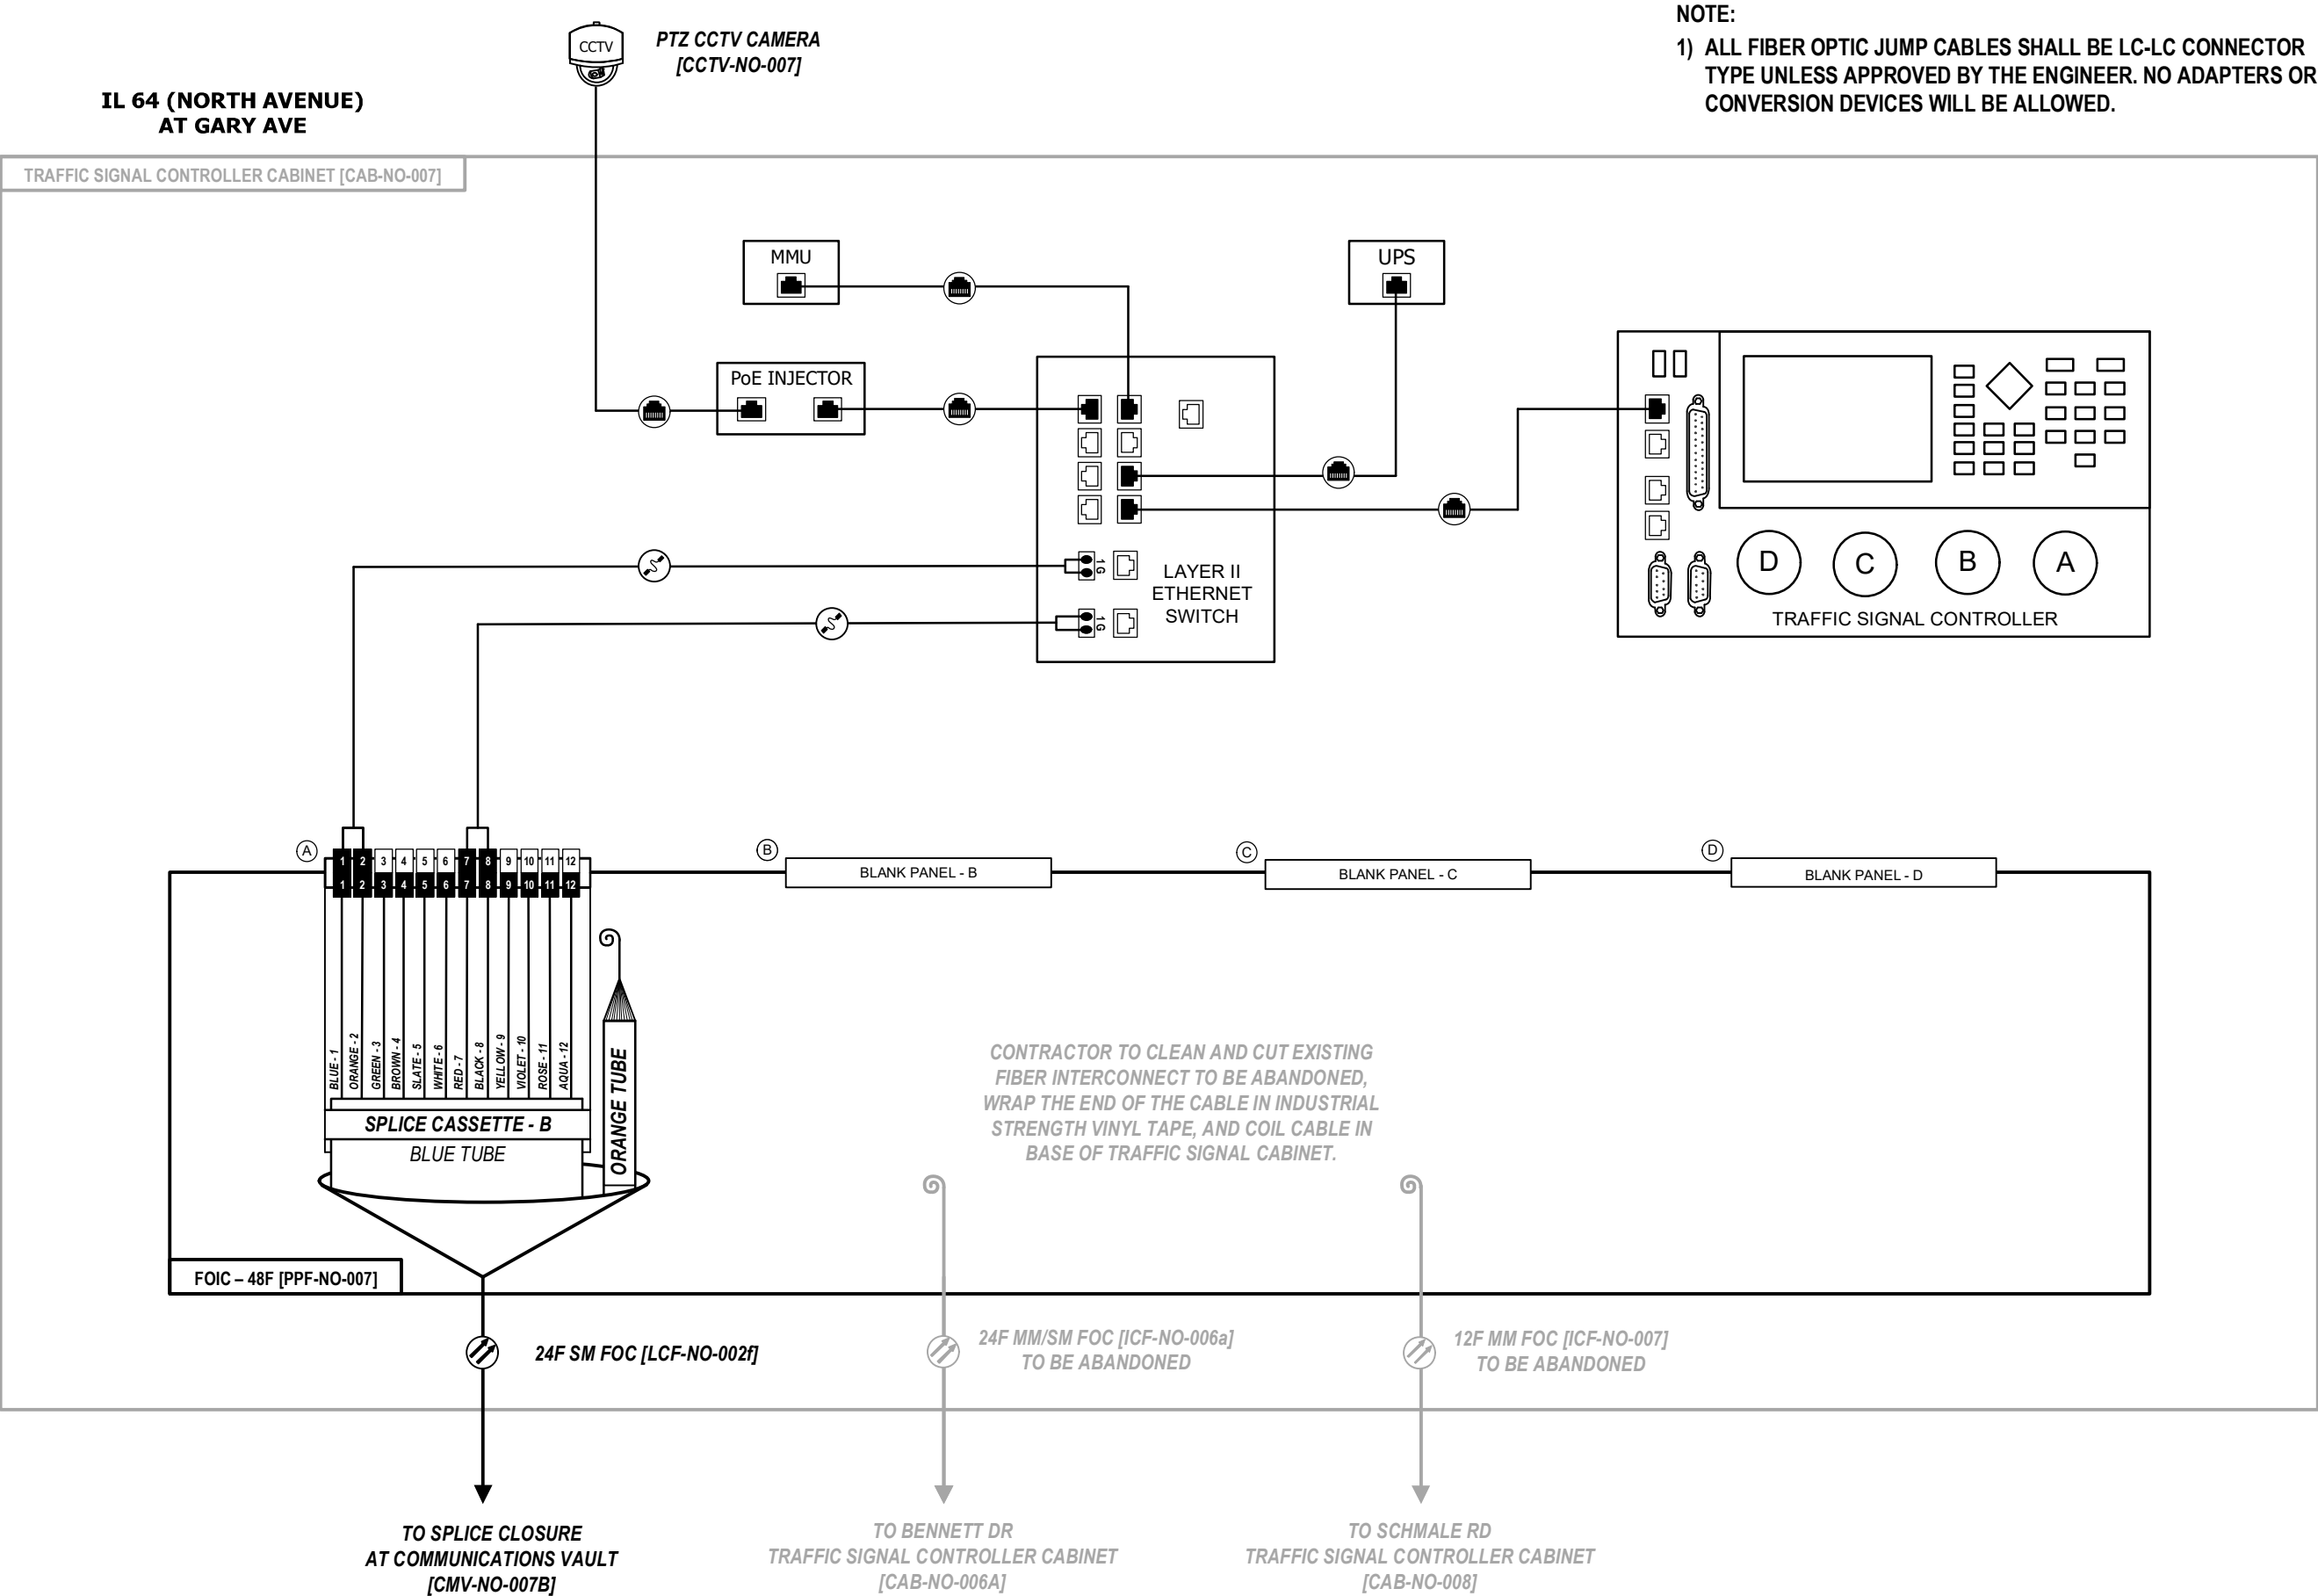

D:\08121-sht-comm-viso

Kimley»Horn


USER NAME =	DESIGNED -	REVISED -
	DRAWN -	REVISED -
PLOT SCALE = N.T.S.	CHECKED -	REVISED -
PLOT DATE =	DATE -	REVISED -

STATE OF ILLINOIS
DEPARTMENT OF TRANSPORTATION

FIBER SPLICING AND CABINET CONNECTION DETAILS
TRAFFIC SIGNAL CONTROLLER CABINET [CAB-NO-007]

SCALE: SHEET OF SHEETS STA. TO STA.

F.A.P. RTE.	SECTION	COUNTY	TOTAL SHEETS	SHEET NO.
307	2020-263-SUR,SW&TS	DUPAGE	529	405
CONTRACT NO. 62N33				
ILLINOIS FED. AID PROJECT				

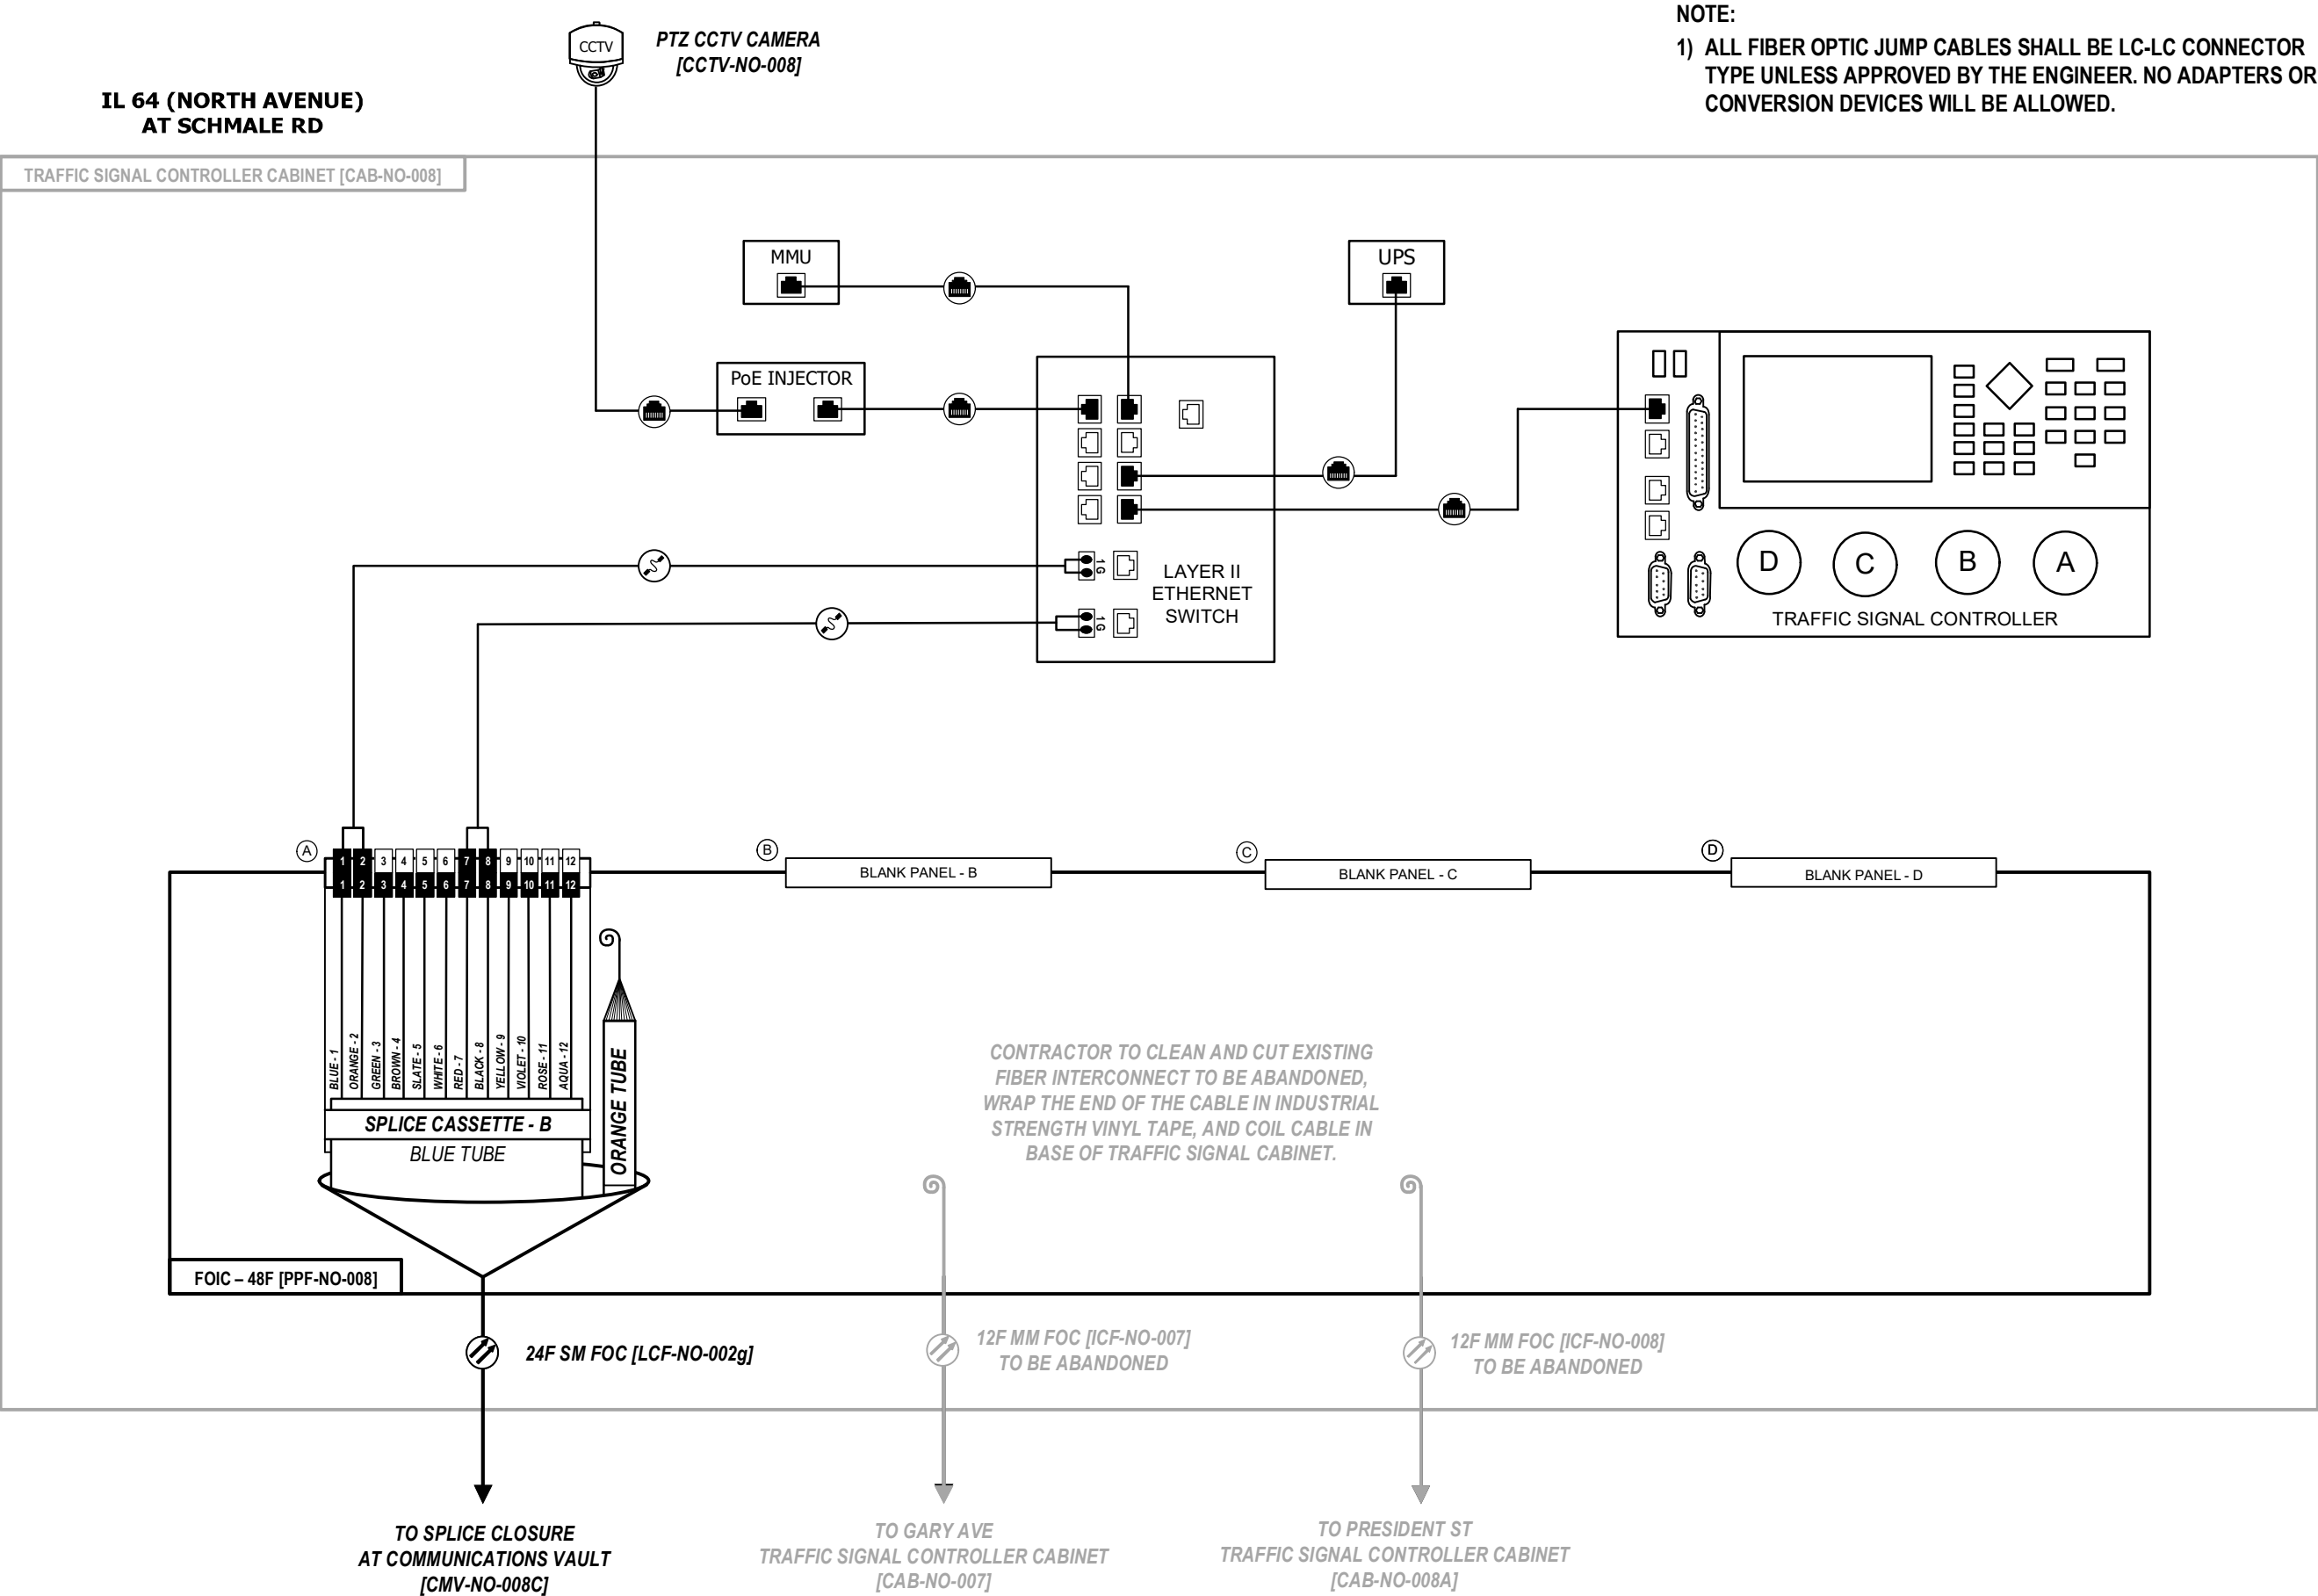

D:\08121-sht-comm-visio

Kimley»Horn

USER NAME =	DESIGNED -	REVISED -
	DRAWN -	REVISED -
PLOT SCALE = N.T.S.	CHECKED -	REVISED -
PLOT DATE =	DATE -	REVISED -


STATE OF ILLINOIS
DEPARTMENT OF TRANSPORTATION

FIBER SPLICING AND CABINET CONNECTION DETAILS
TRAFFIC SIGNAL CONTROLLER CABINET [CAB-NO-008]

SCALE: SHEET OF SHEETS STA. TO STA.

F.A.P. RTE.	SECTION	COUNTY	TOTAL SHEETS	SHEET NO.
307	2020-263-SUR,SW&TS	DUPAGE	529	406
CONTRACT NO. 62N33				
ILLINOIS FED. AID PROJECT				

IL 64 (NORTH AVENUE)
AT PRESIDENT ST

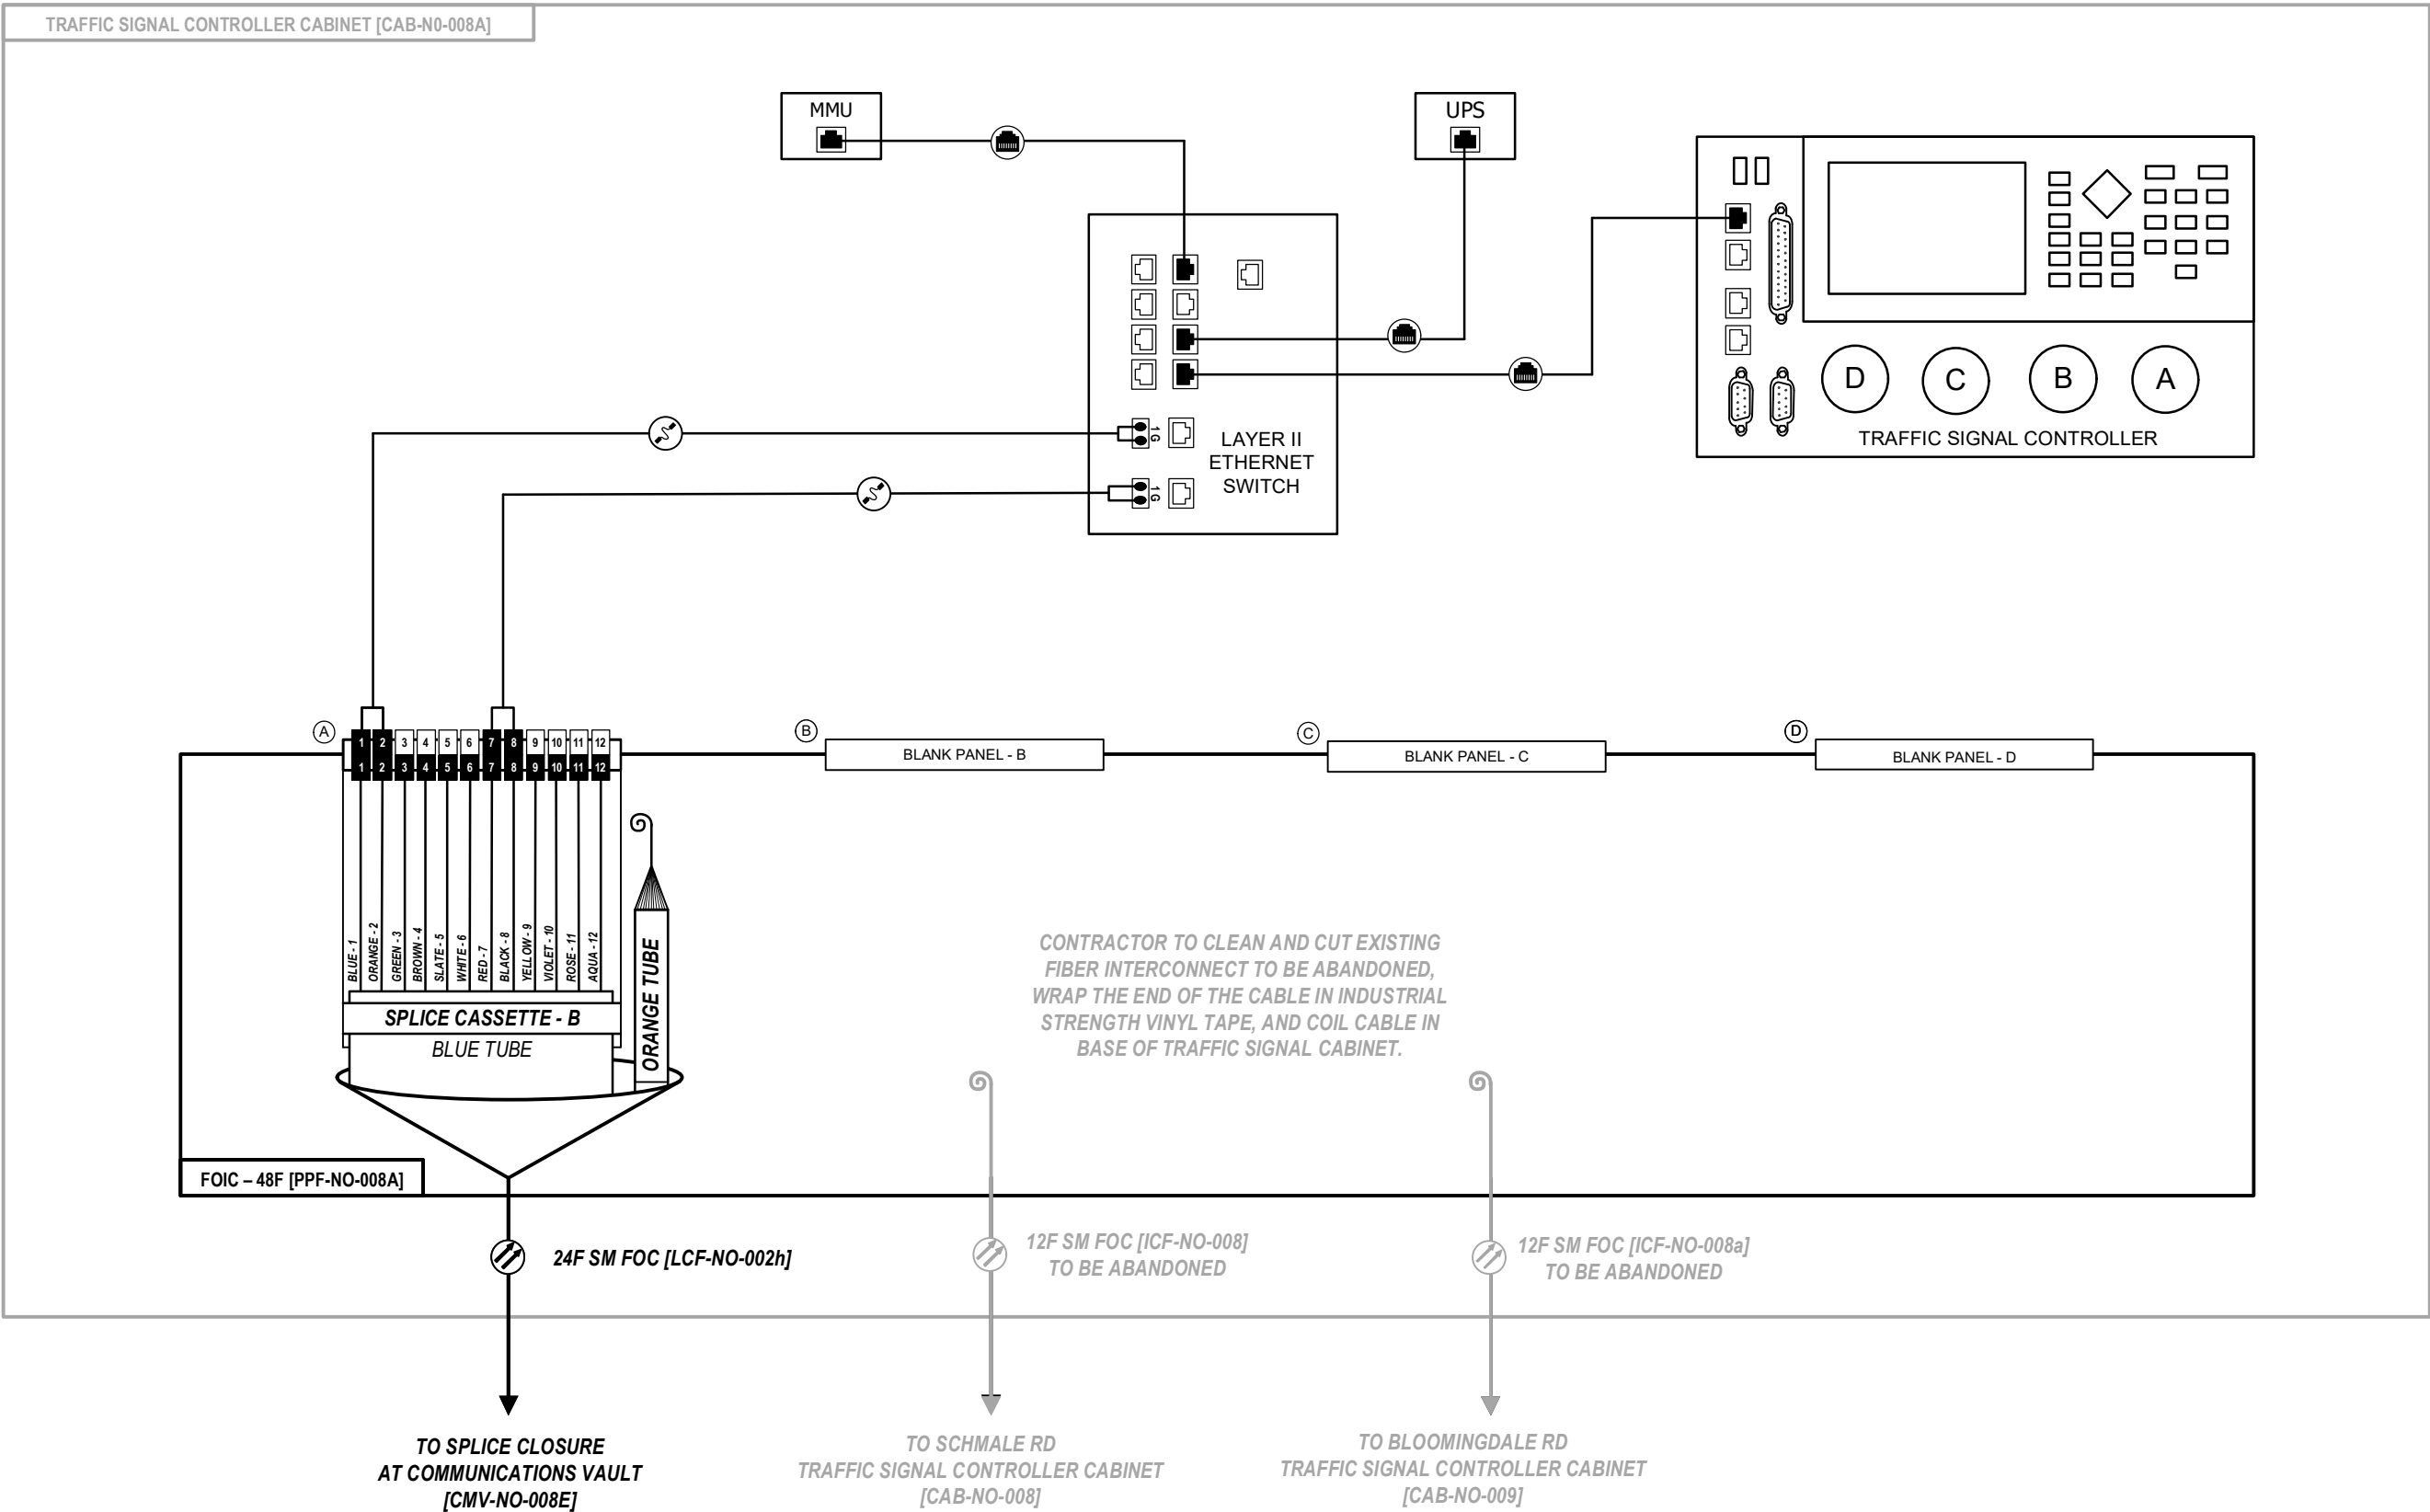

NOTE:
1) ALL FIBER OPTIC JUMP CABLES SHALL BE LC-LC CONNECTOR
TYPE UNLESS APPROVED BY THE ENGINEER. NO ADAPTERS OR
CONVERSION DEVICES WILL BE ALLOWED.

D:\08121-sht-comm-visio

Kimley»Horn


USER NAME =	DESIGNED -	REVISED -
	DRAWN -	REVISED -
PLOT SCALE = N.T.S.	CHECKED -	REVISED -
PLOT DATE =	DATE -	REVISED -

STATE OF ILLINOIS
DEPARTMENT OF TRANSPORTATION

FIBER SPLICING AND CABINET CONNECTION DETAILS
TRAFFIC SIGNAL CONTROLLER CABINET [CAB-NO-008A]

SCALE:	SHEET	OF	SHEETS	STA.	TO STA.
--------	-------	----	--------	------	---------

F.A.P. RTE.	SECTION	COUNTY	TOTAL SHEETS	SHEET NO.
307	2020-263-SUR,SW&TS	DUPAGE	529	407
CONTRACT NO. 62N33				
ILLINOIS				

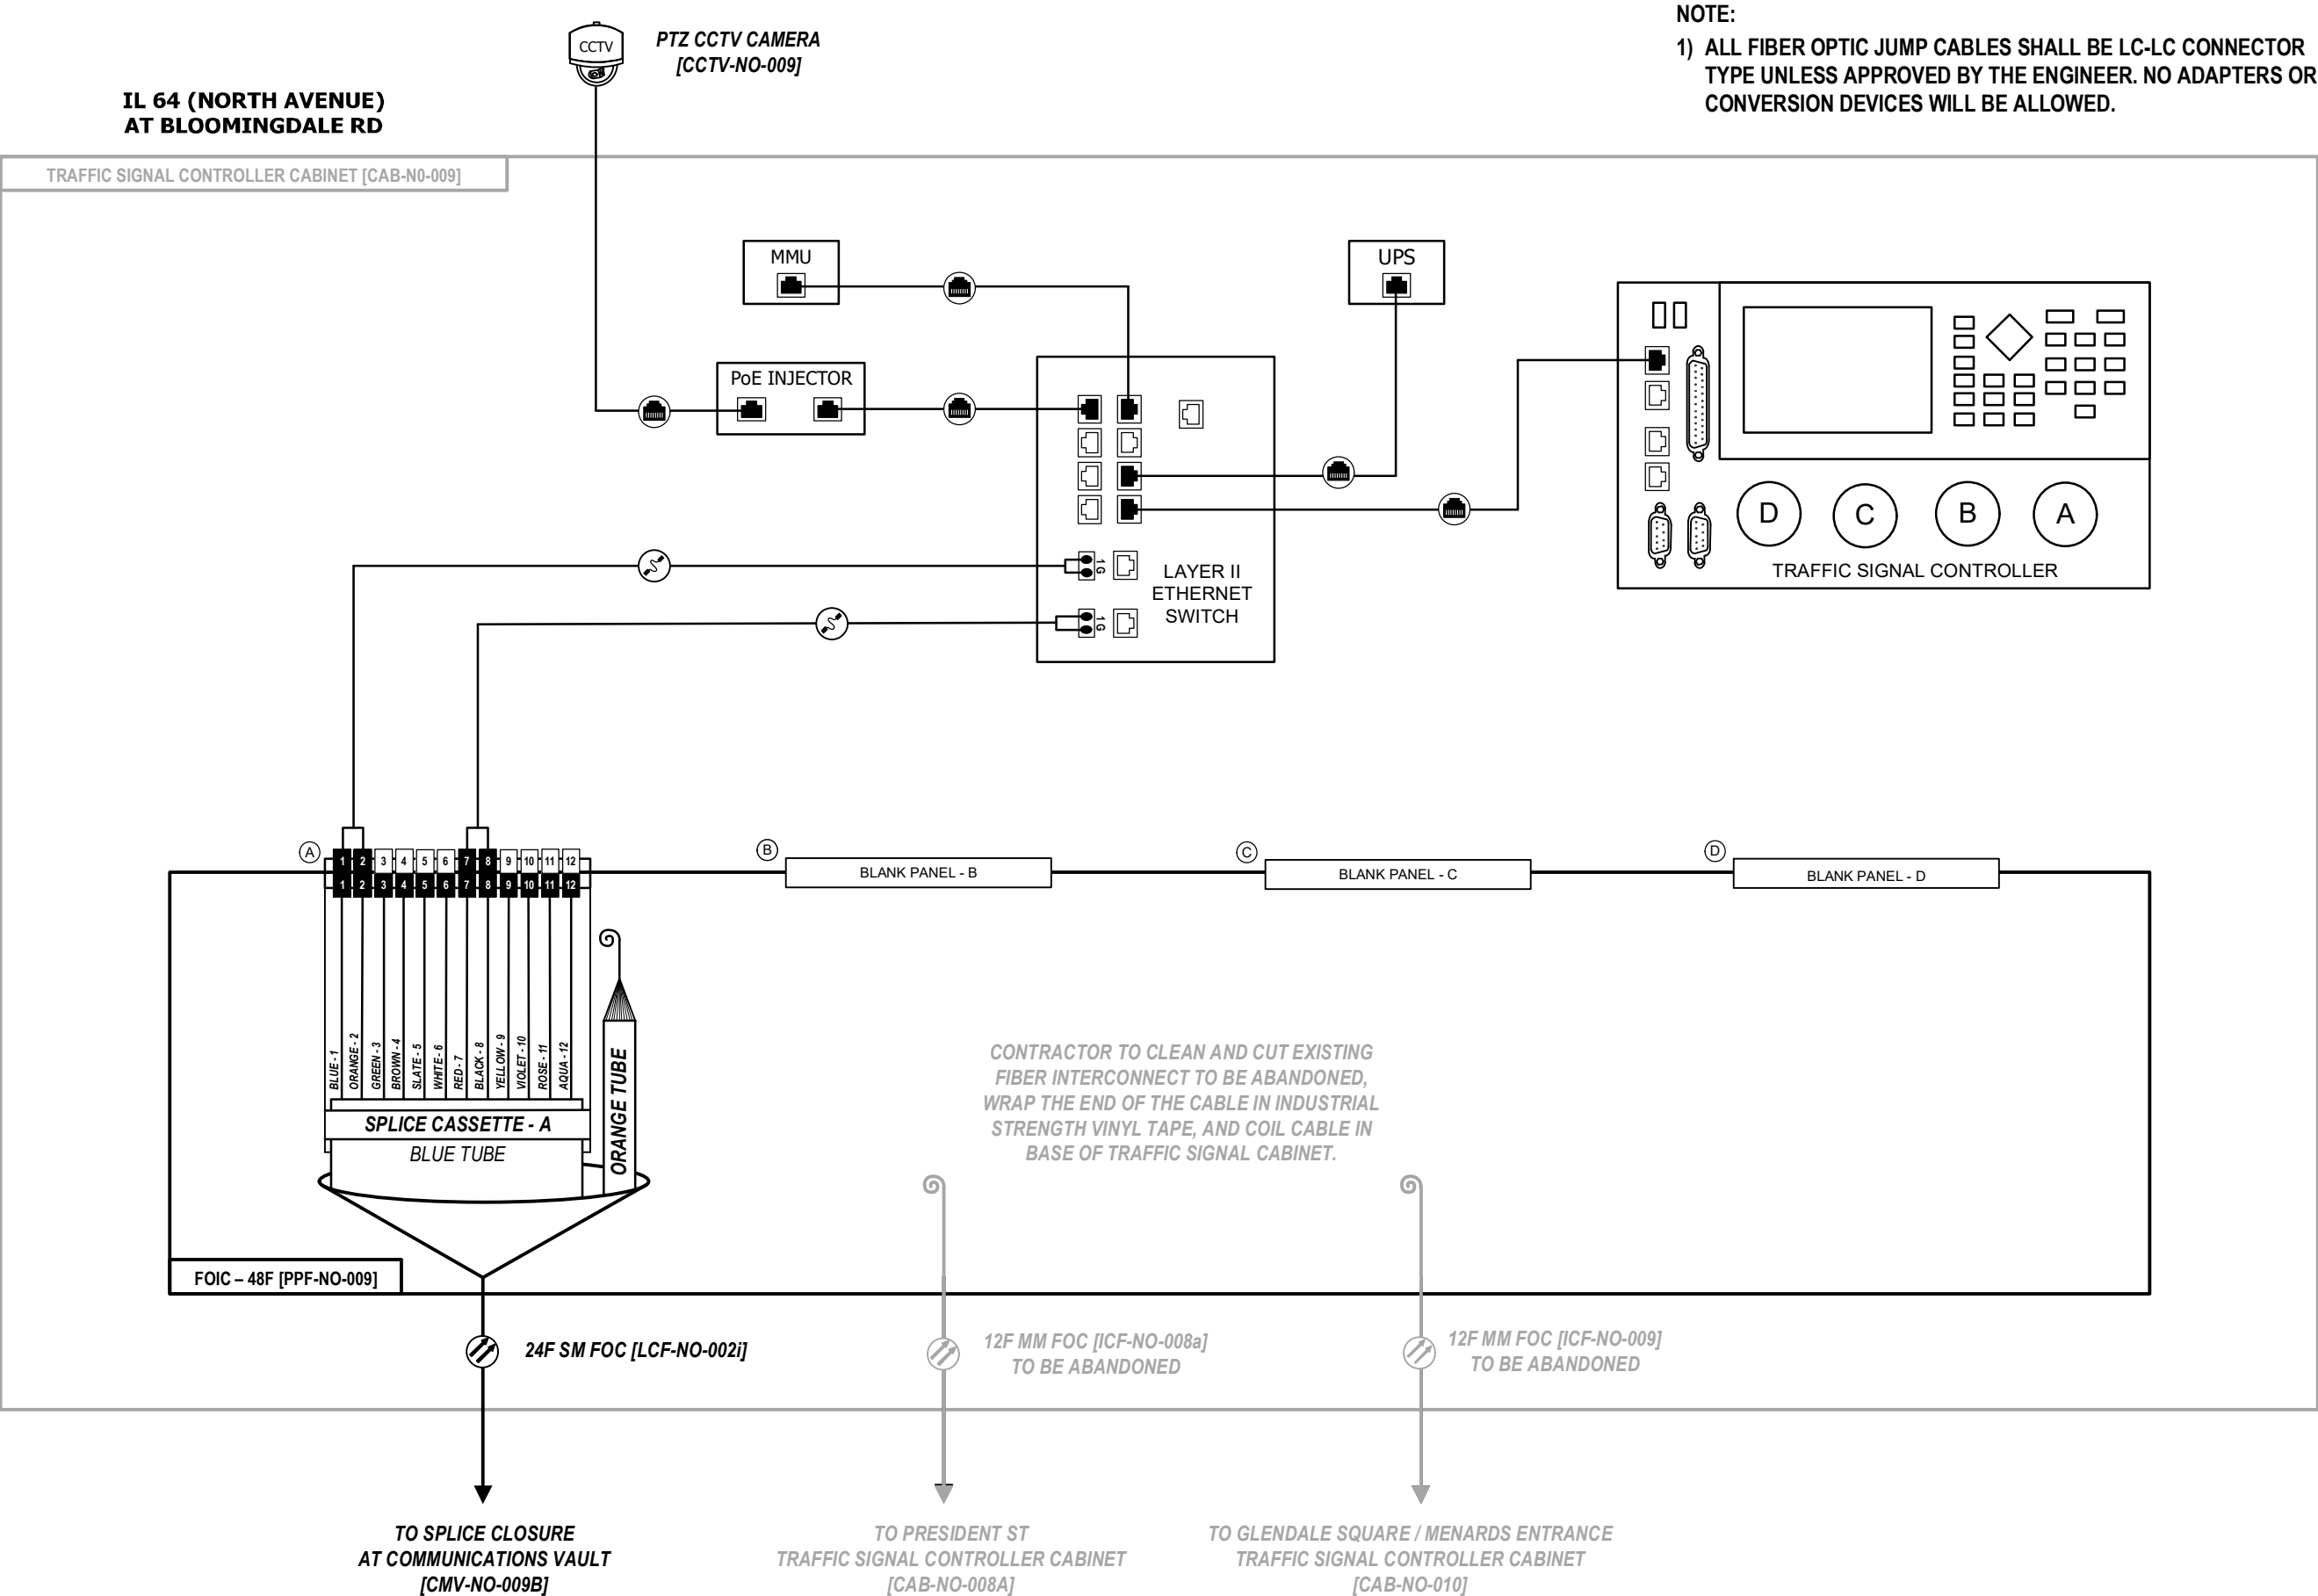

D:\08121-sht-comm-viso

TRAFFIC SIGNAL CONTROLLER CABINET [CAB-NO-010]

MMU

UPS

LAYER II ETHERNET SWITCH

TRAFFIC SIGNAL CONTROLLER

SPLICE CASSETTE - A

BLUE TUBE

ORANGE TUBE

FOIC - 48F [PPF-NO-010]

24F SM FOC [LCF-NO-002]

12F MM FOC [ICF-NO-009] TO BE ABANDONED

12F MM FOC [ICF-NO-010] TO BE ABANDONED


TO SPlice CLOSURE AT COMMUNICATIONS VAULT [CMV-NO-010]

TO BLOOMINGDALE RD TRAFFIC SIGNAL CONTROLLER CABINET [CAB-NO-009]

TO GLEN ELLYN RD TRAFFIC SIGNAL CONTROLLER CABINET [CAB-NO-010A]

CONTRACTOR TO CLEAN AND CUT EXISTING FIBER INTERCONNECT TO BE ABANDONED, WRAP THE END OF THE CABLE IN INDUSTRIAL STRENGTH VINYL TAPE, AND COIL CABLE IN BASE OF TRAFFIC SIGNAL CABINET.

1) ALL FIBER OPTIC JUMP CABLES SHALL BE LC-LC CONNECTOR TYPE UNLESS APPROVED BY THE ENGINEER. NO ADAPTERS OR CONVERSION DEVICES WILL BE ALLOWED.

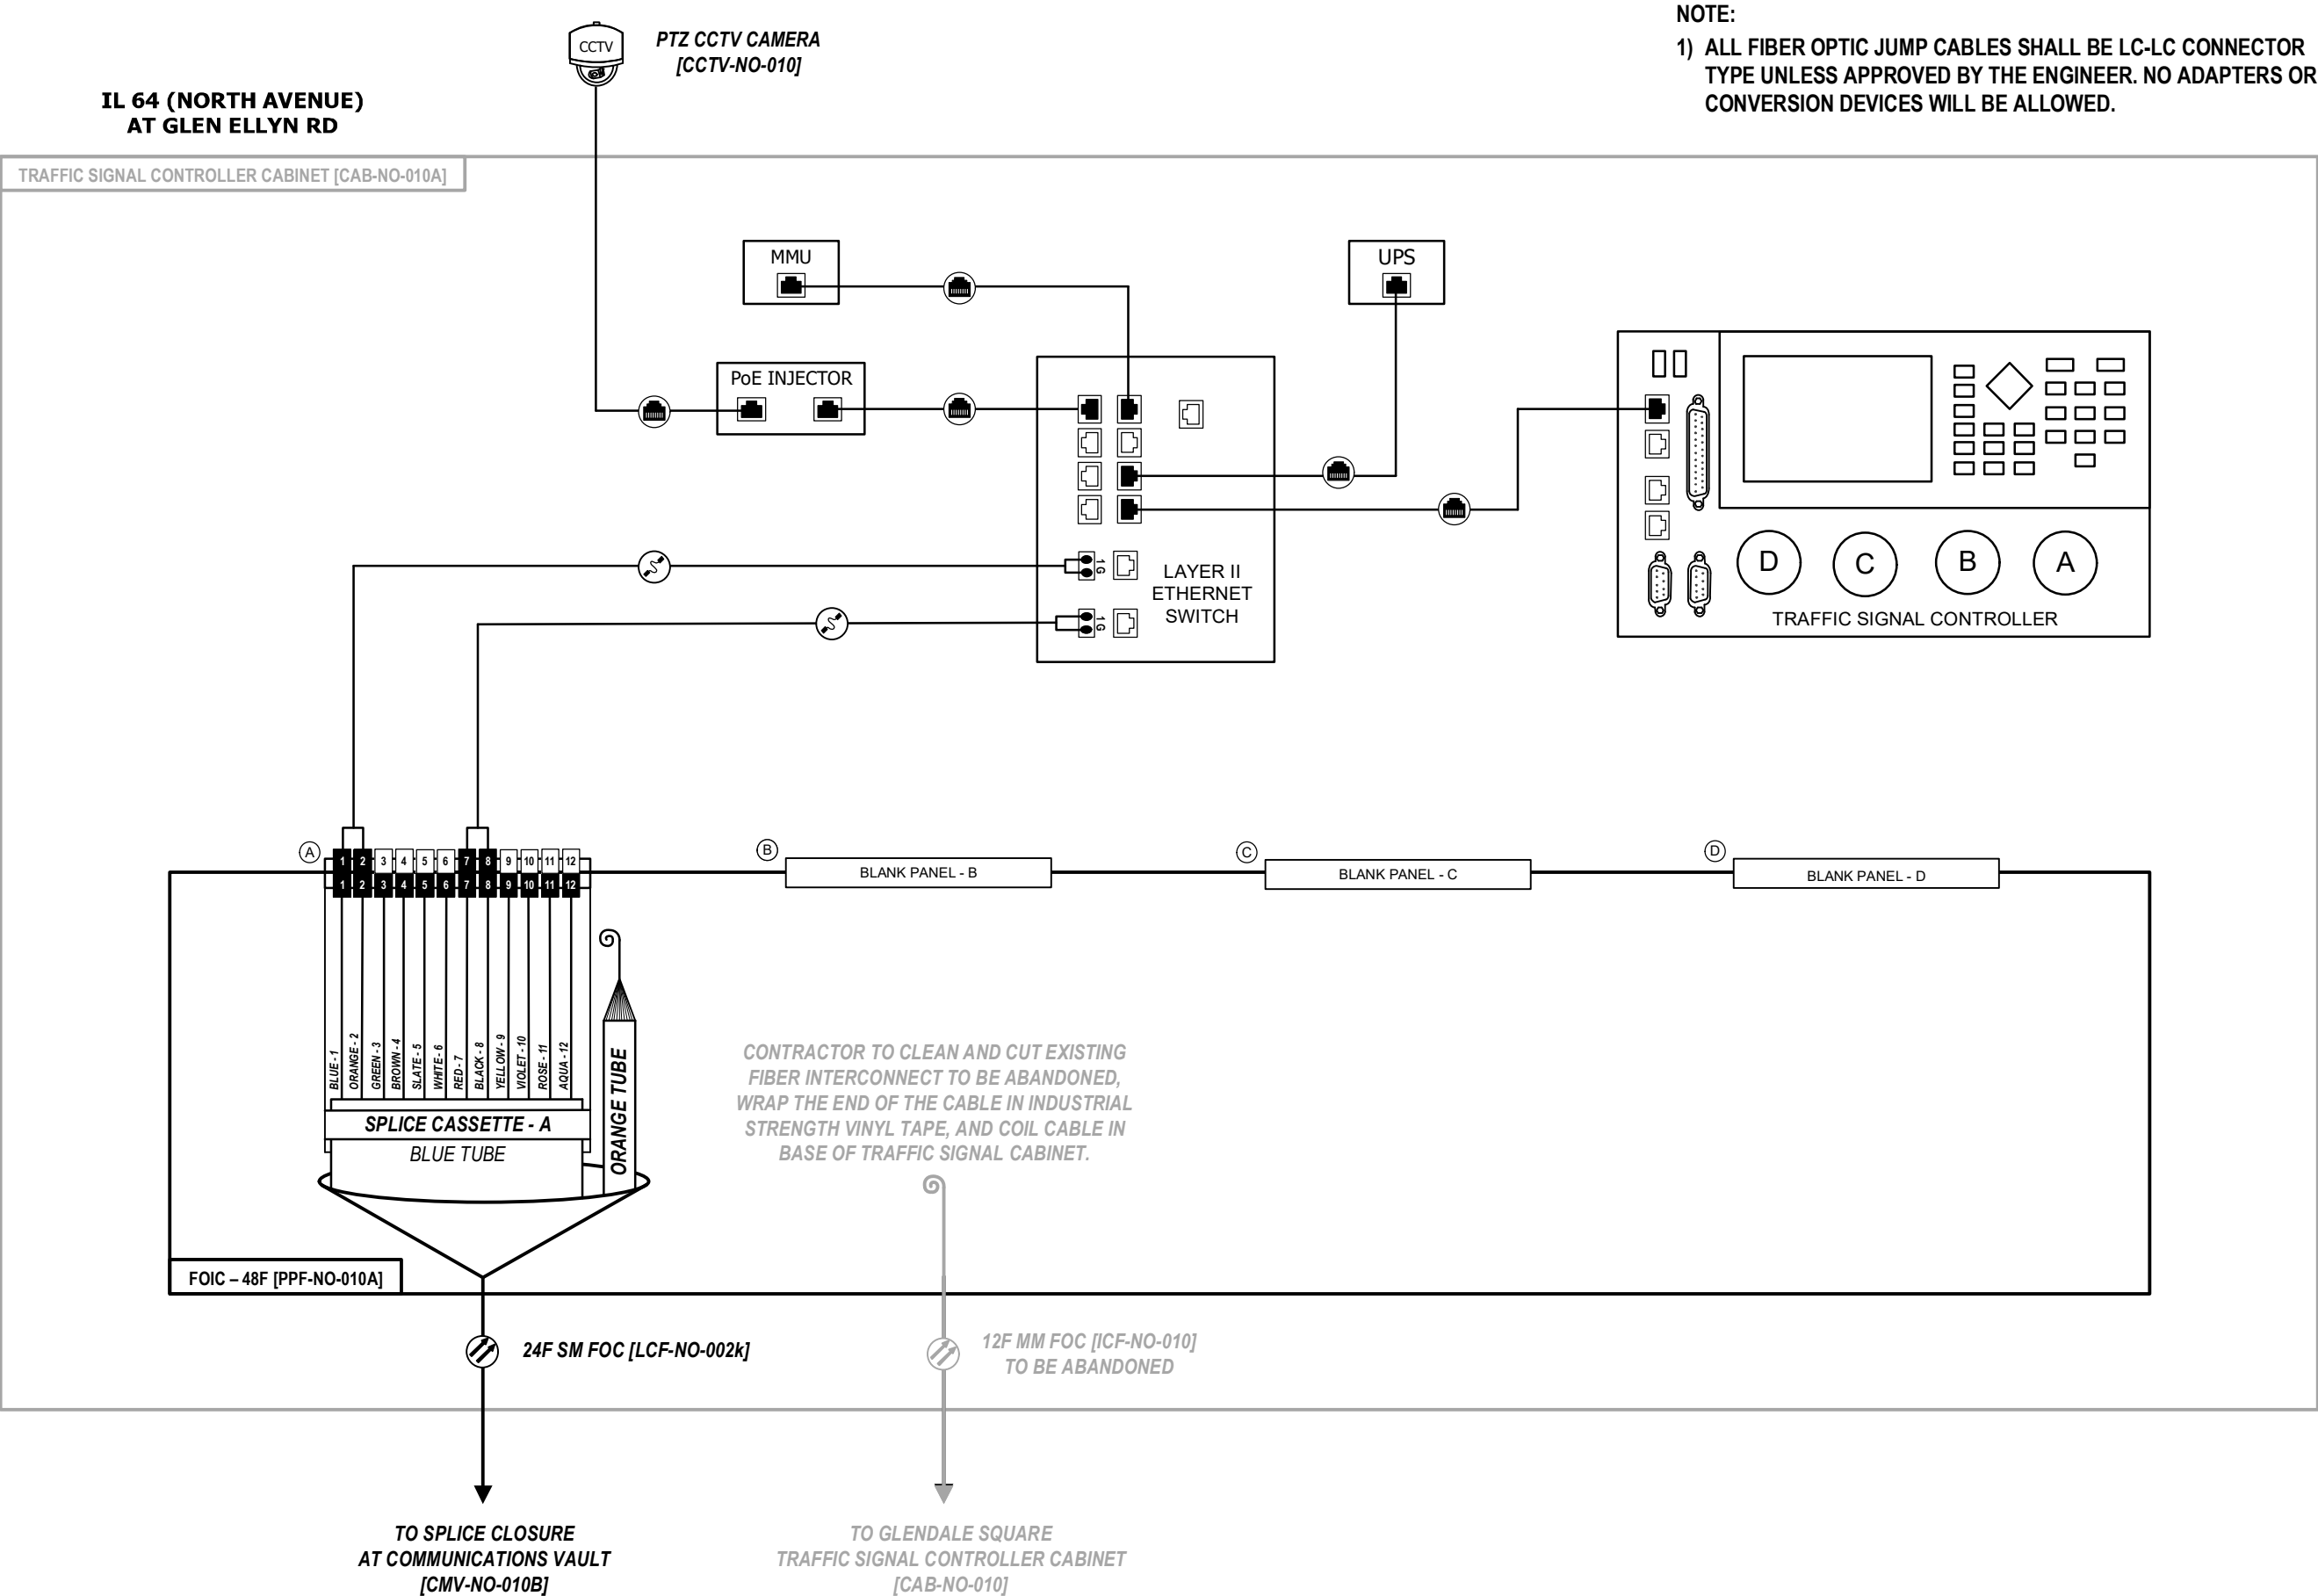

D:\08121-sht-comm-visio

Kimley»Horn


USER NAME =	DESIGNED -	REVISED -
	DRAWN -	REVISED -
PLOT SCALE = N.T.S.	CHECKED -	REVISED -
PLOT DATE =	DATE -	REVISED -

STATE OF ILLINOIS
DEPARTMENT OF TRANSPORTATION


FIBER SPLICING AND CABINET CONNECTION DETAILS
TRAFFIC SIGNAL CONTROLLER CABINET [CAB-NO-010A]

SCALE: SHEET OF SHEETS STA. TO STA.

F.A.P. RTE.	SECTION	COUNTY	TOTAL SHEETS	SHEET NO.
307	2020-263-SUR,SW&TS	DUPAGE	529	410
CONTRACT NO. 62N33				
ILLINOIS FED. AID PROJECT				

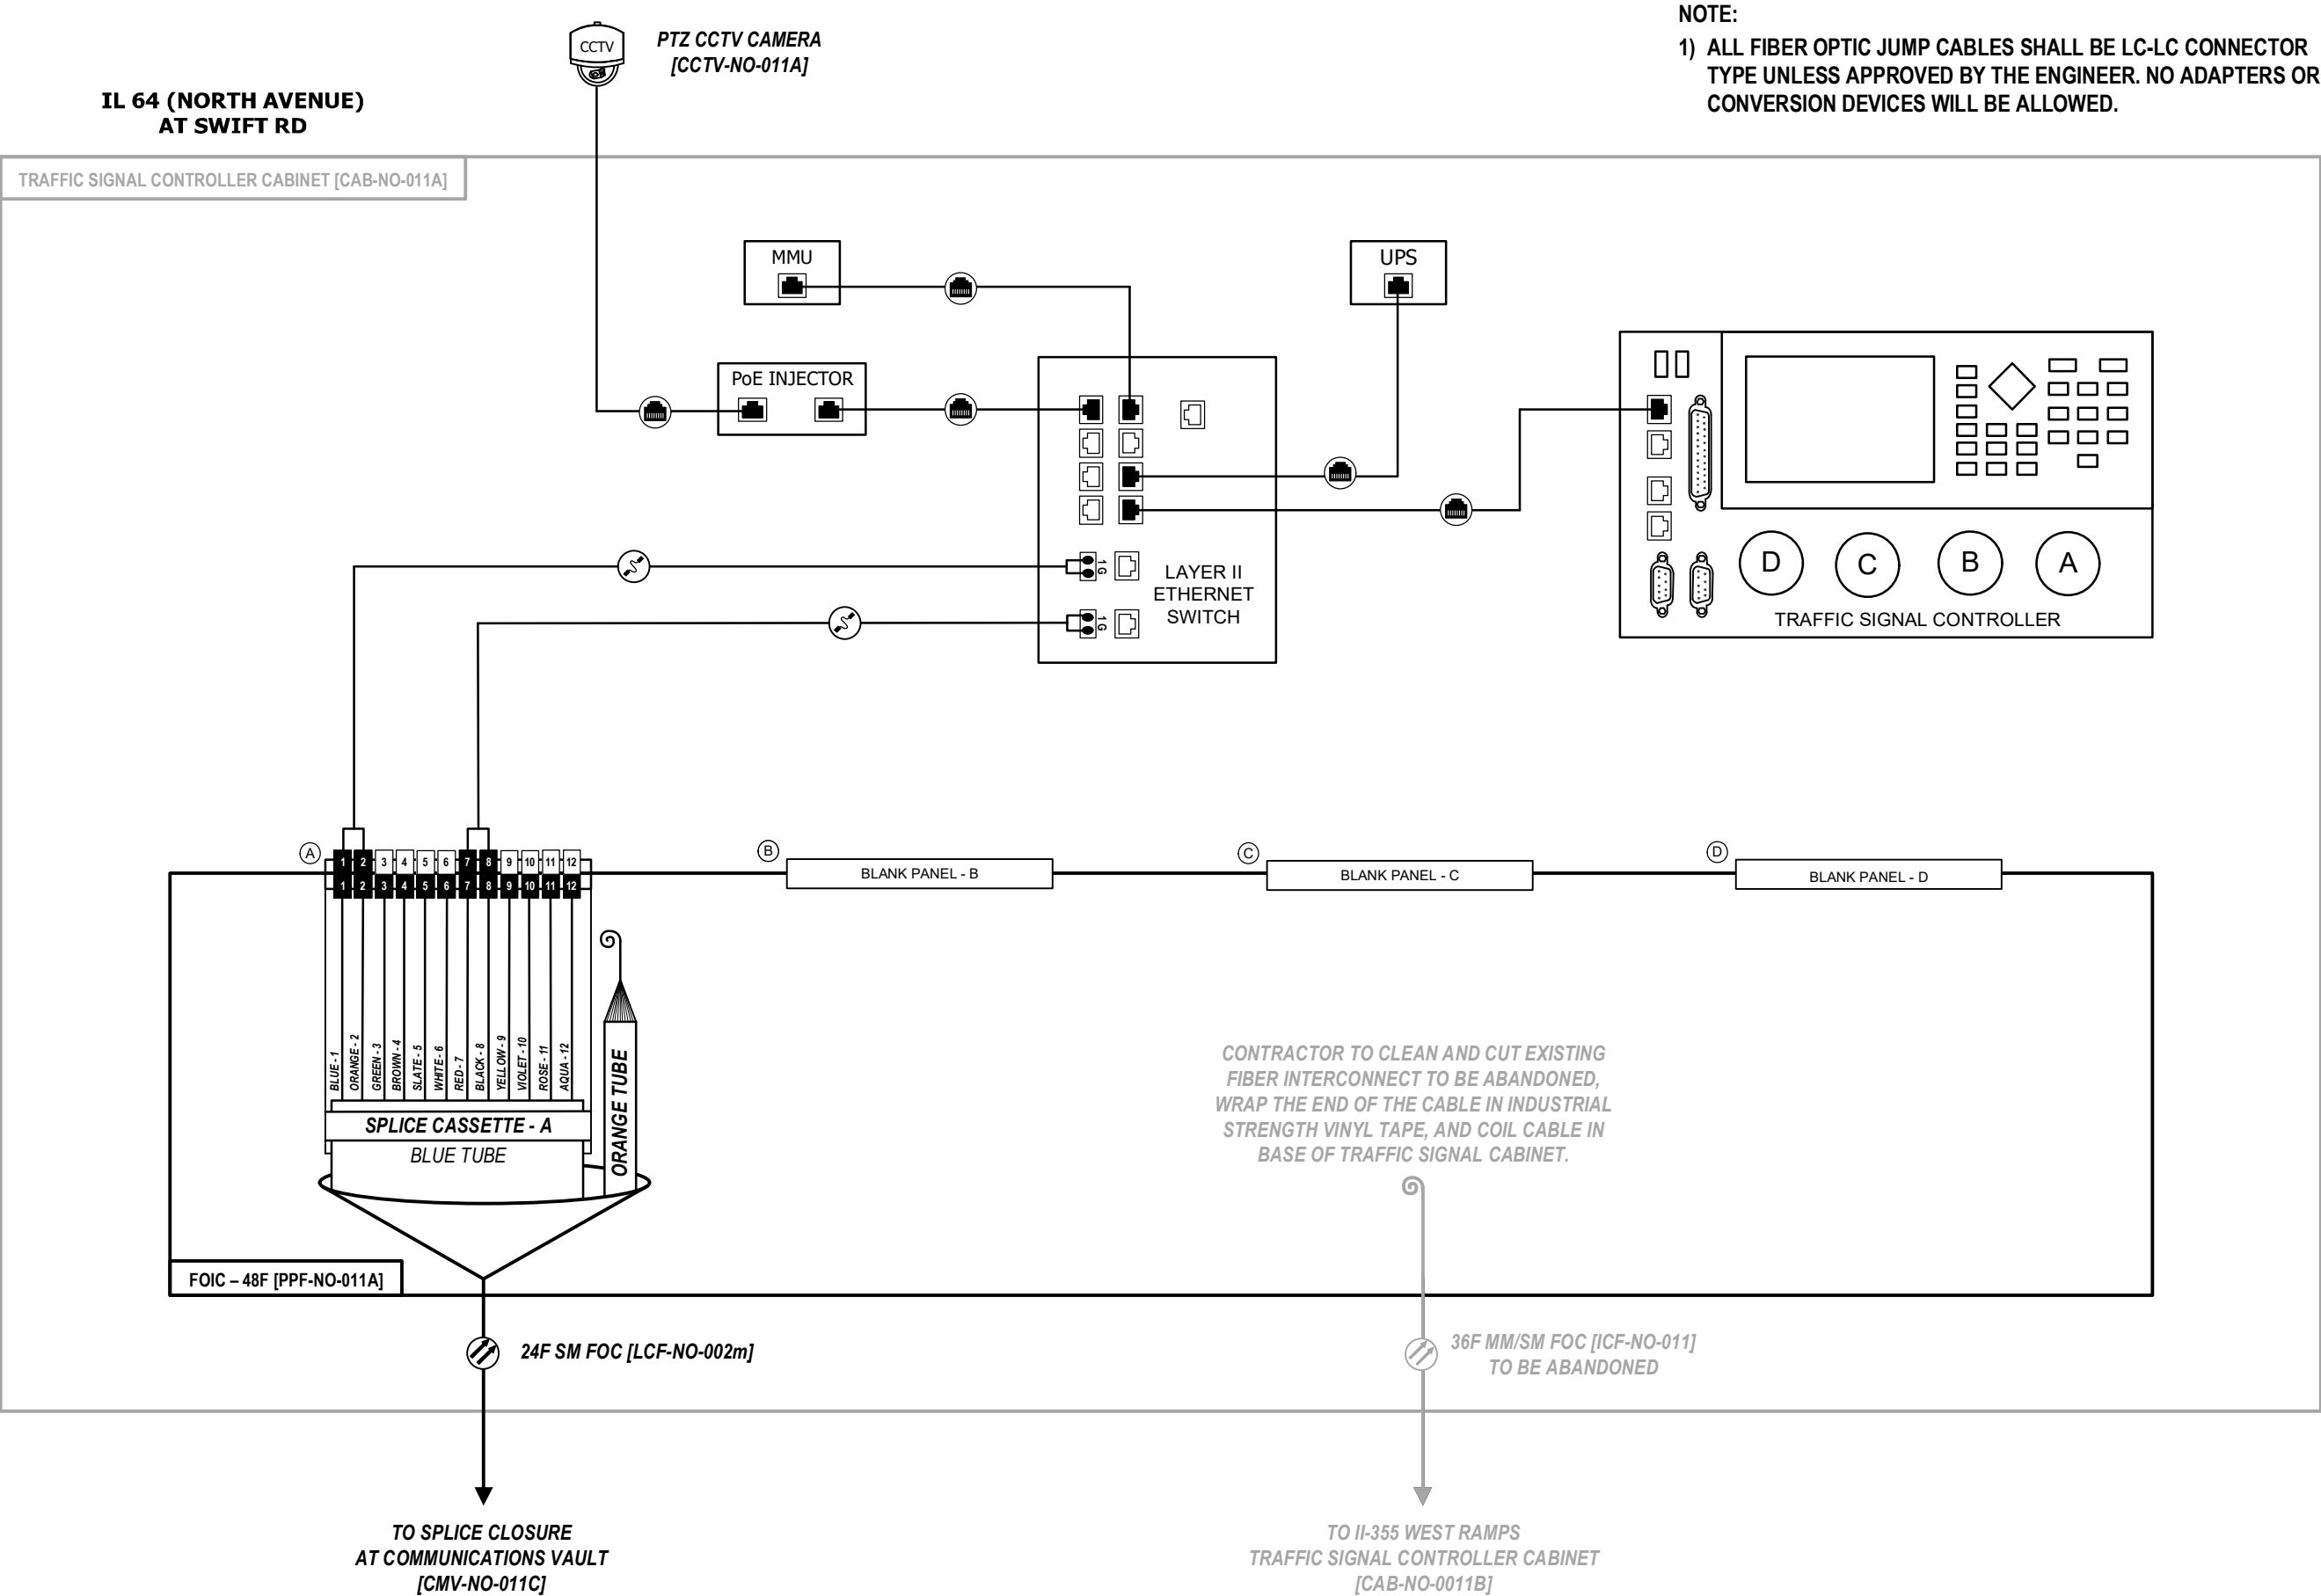

D:\08121-sht-comm-visio

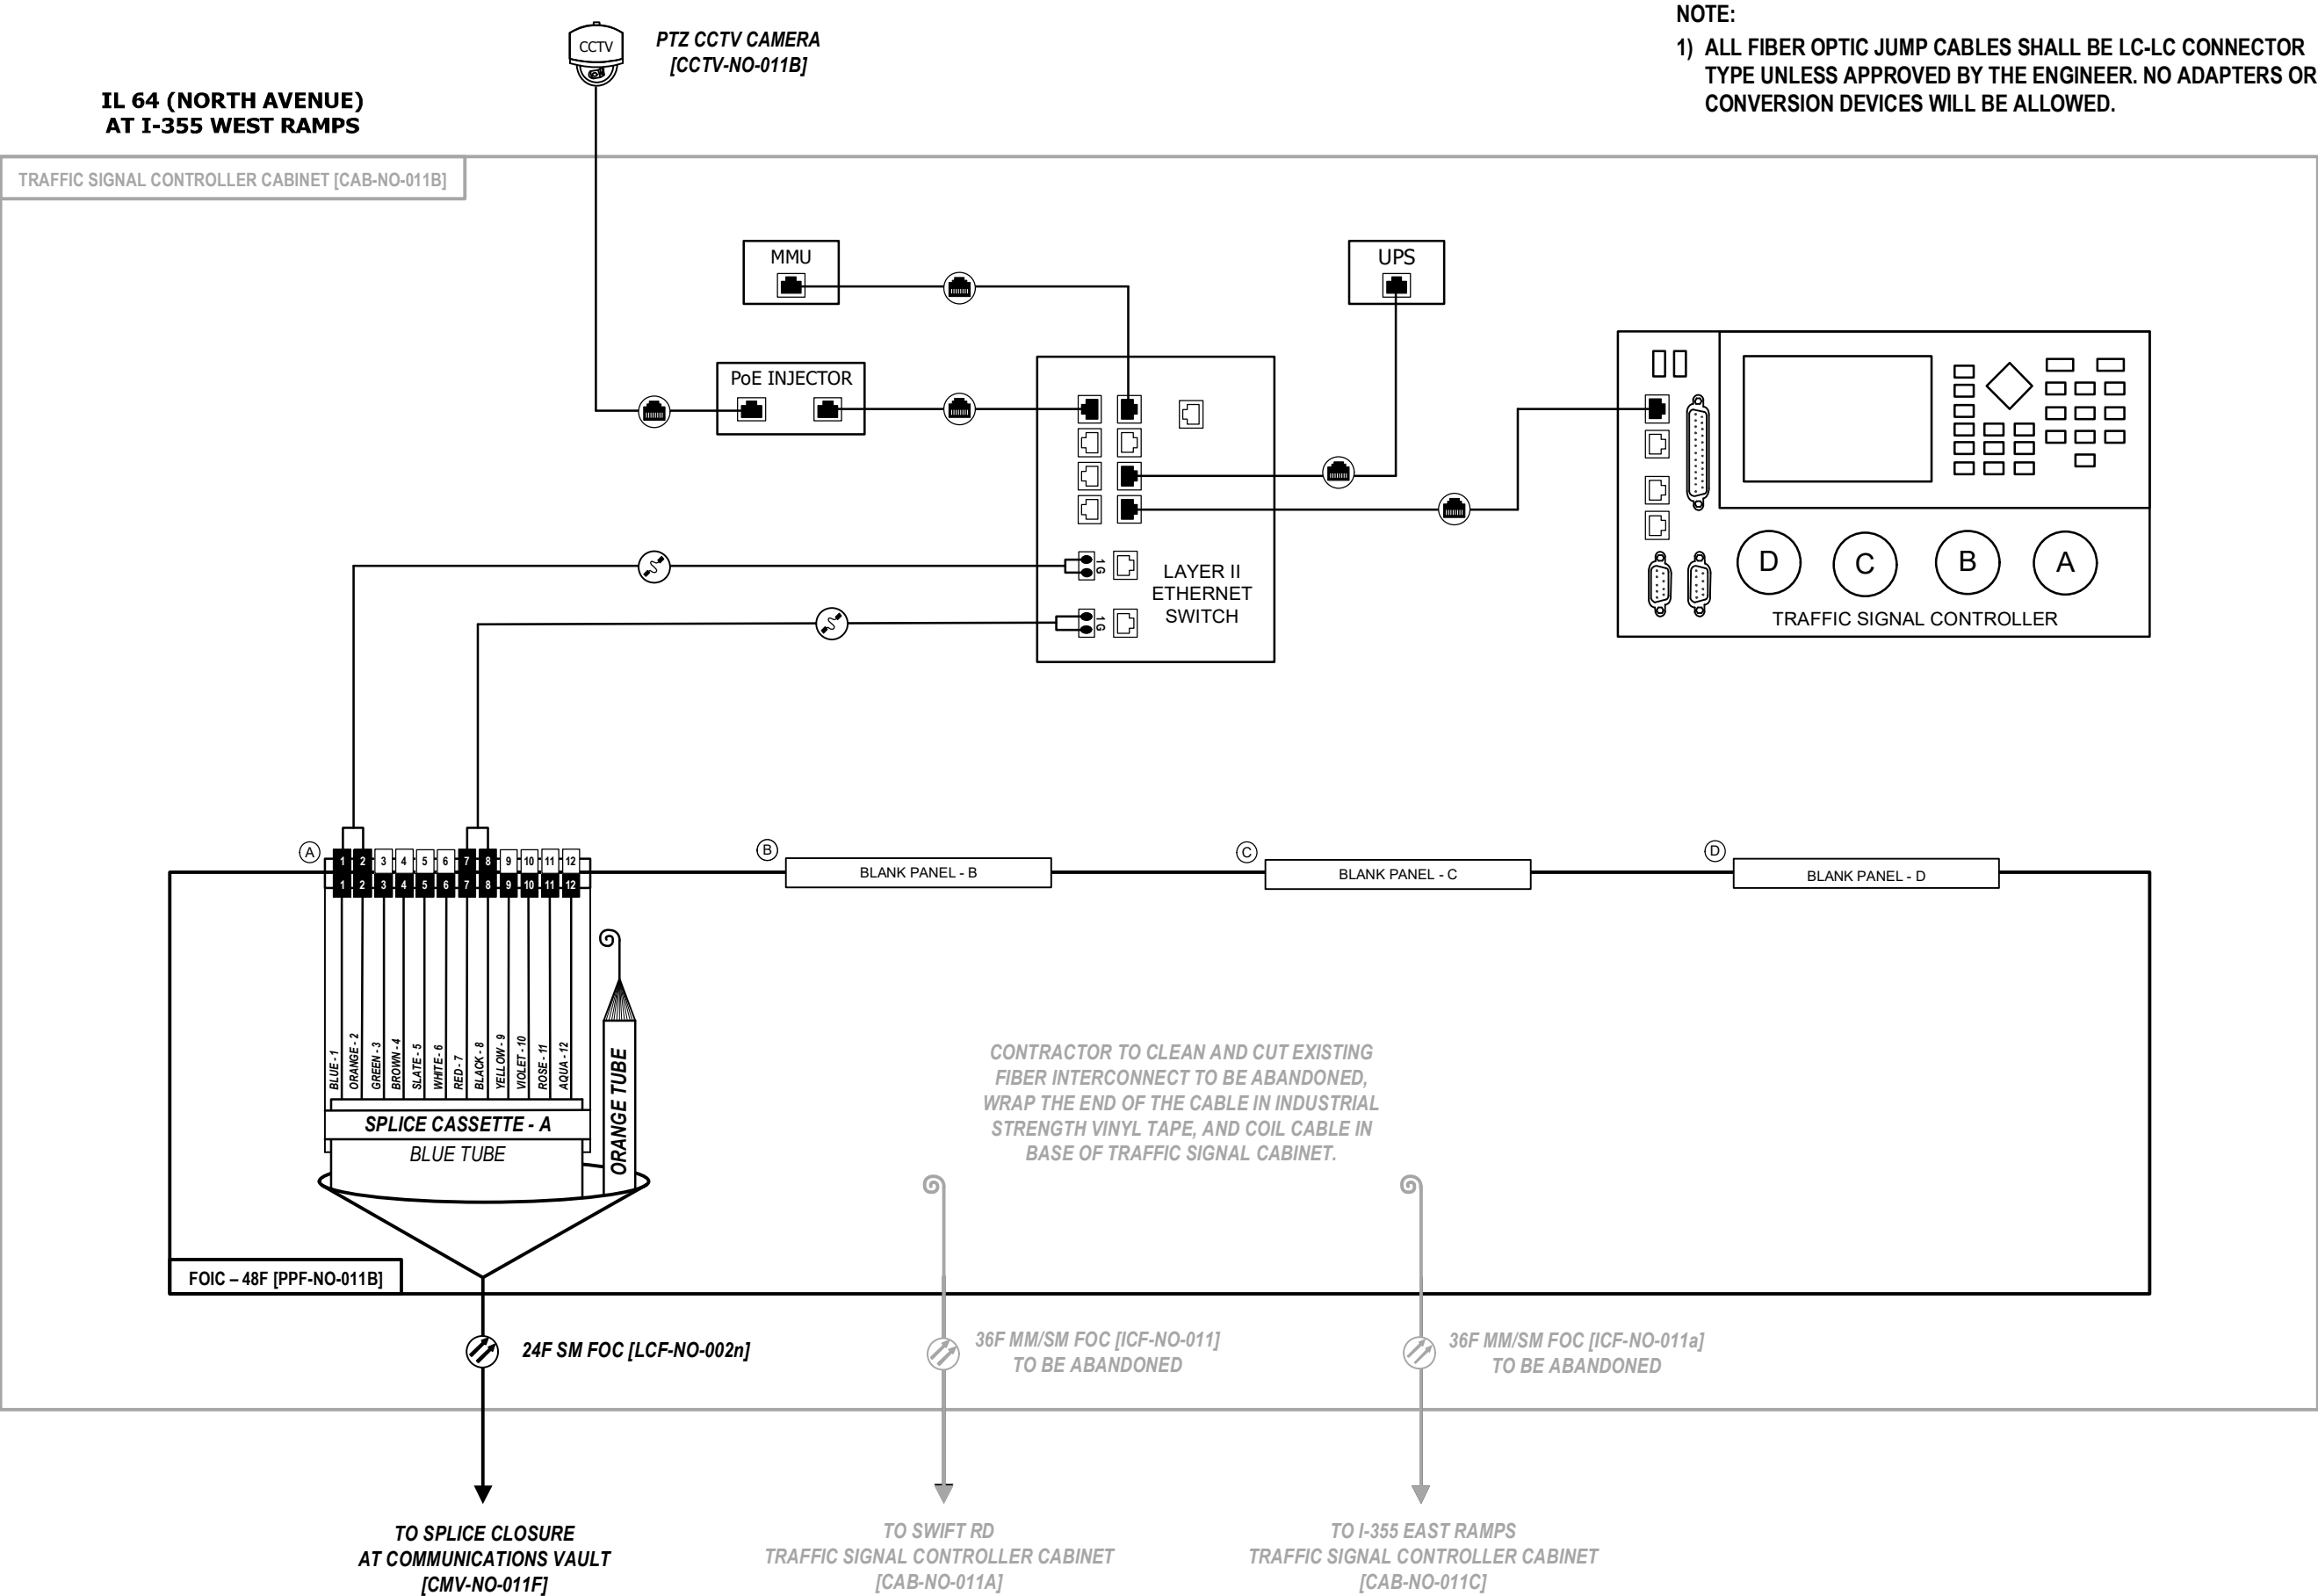

D:\08121-sht-comm-visio

Kimley»Horn

USER NAME =	DESIGNED -	REVISED -
	DRAWN -	REVISED -
PLOT SCALE = N.T.S.	CHECKED -	REVISED -
PLOT DATE =	DATE -	REVISED -

STATE OF ILLINOIS
DEPARTMENT OF TRANSPORTATION


FIBER SPLICING AND CABINET CONNECTION DETAILS
TRAFFIC SIGNAL CONTROLLER CABINET [CAB-NO-011B]

SCALE: SHEET OF SHEETS STA. TO STA.

F.A.P. RTE.	SECTION	COUNTY	TOTAL SHEETS	SHEET NO.
307	2020-263-SUR,SW&TS	DUPAGE	529	413
CONTRACT NO. 62N33				
ILLINOIS FED. AID PROJECT				

IL 64 (NORTH AVENUE)
AT I-355 EAST RAMP

NOTE:
1) ALL FIBER OPTIC JUMP CABLES SHALL BE LC-LC CONNECTOR
TYPE UNLESS APPROVED BY THE ENGINEER. NO ADAPTERS OR
CONVERSION DEVICES WILL BE ALLOWED.

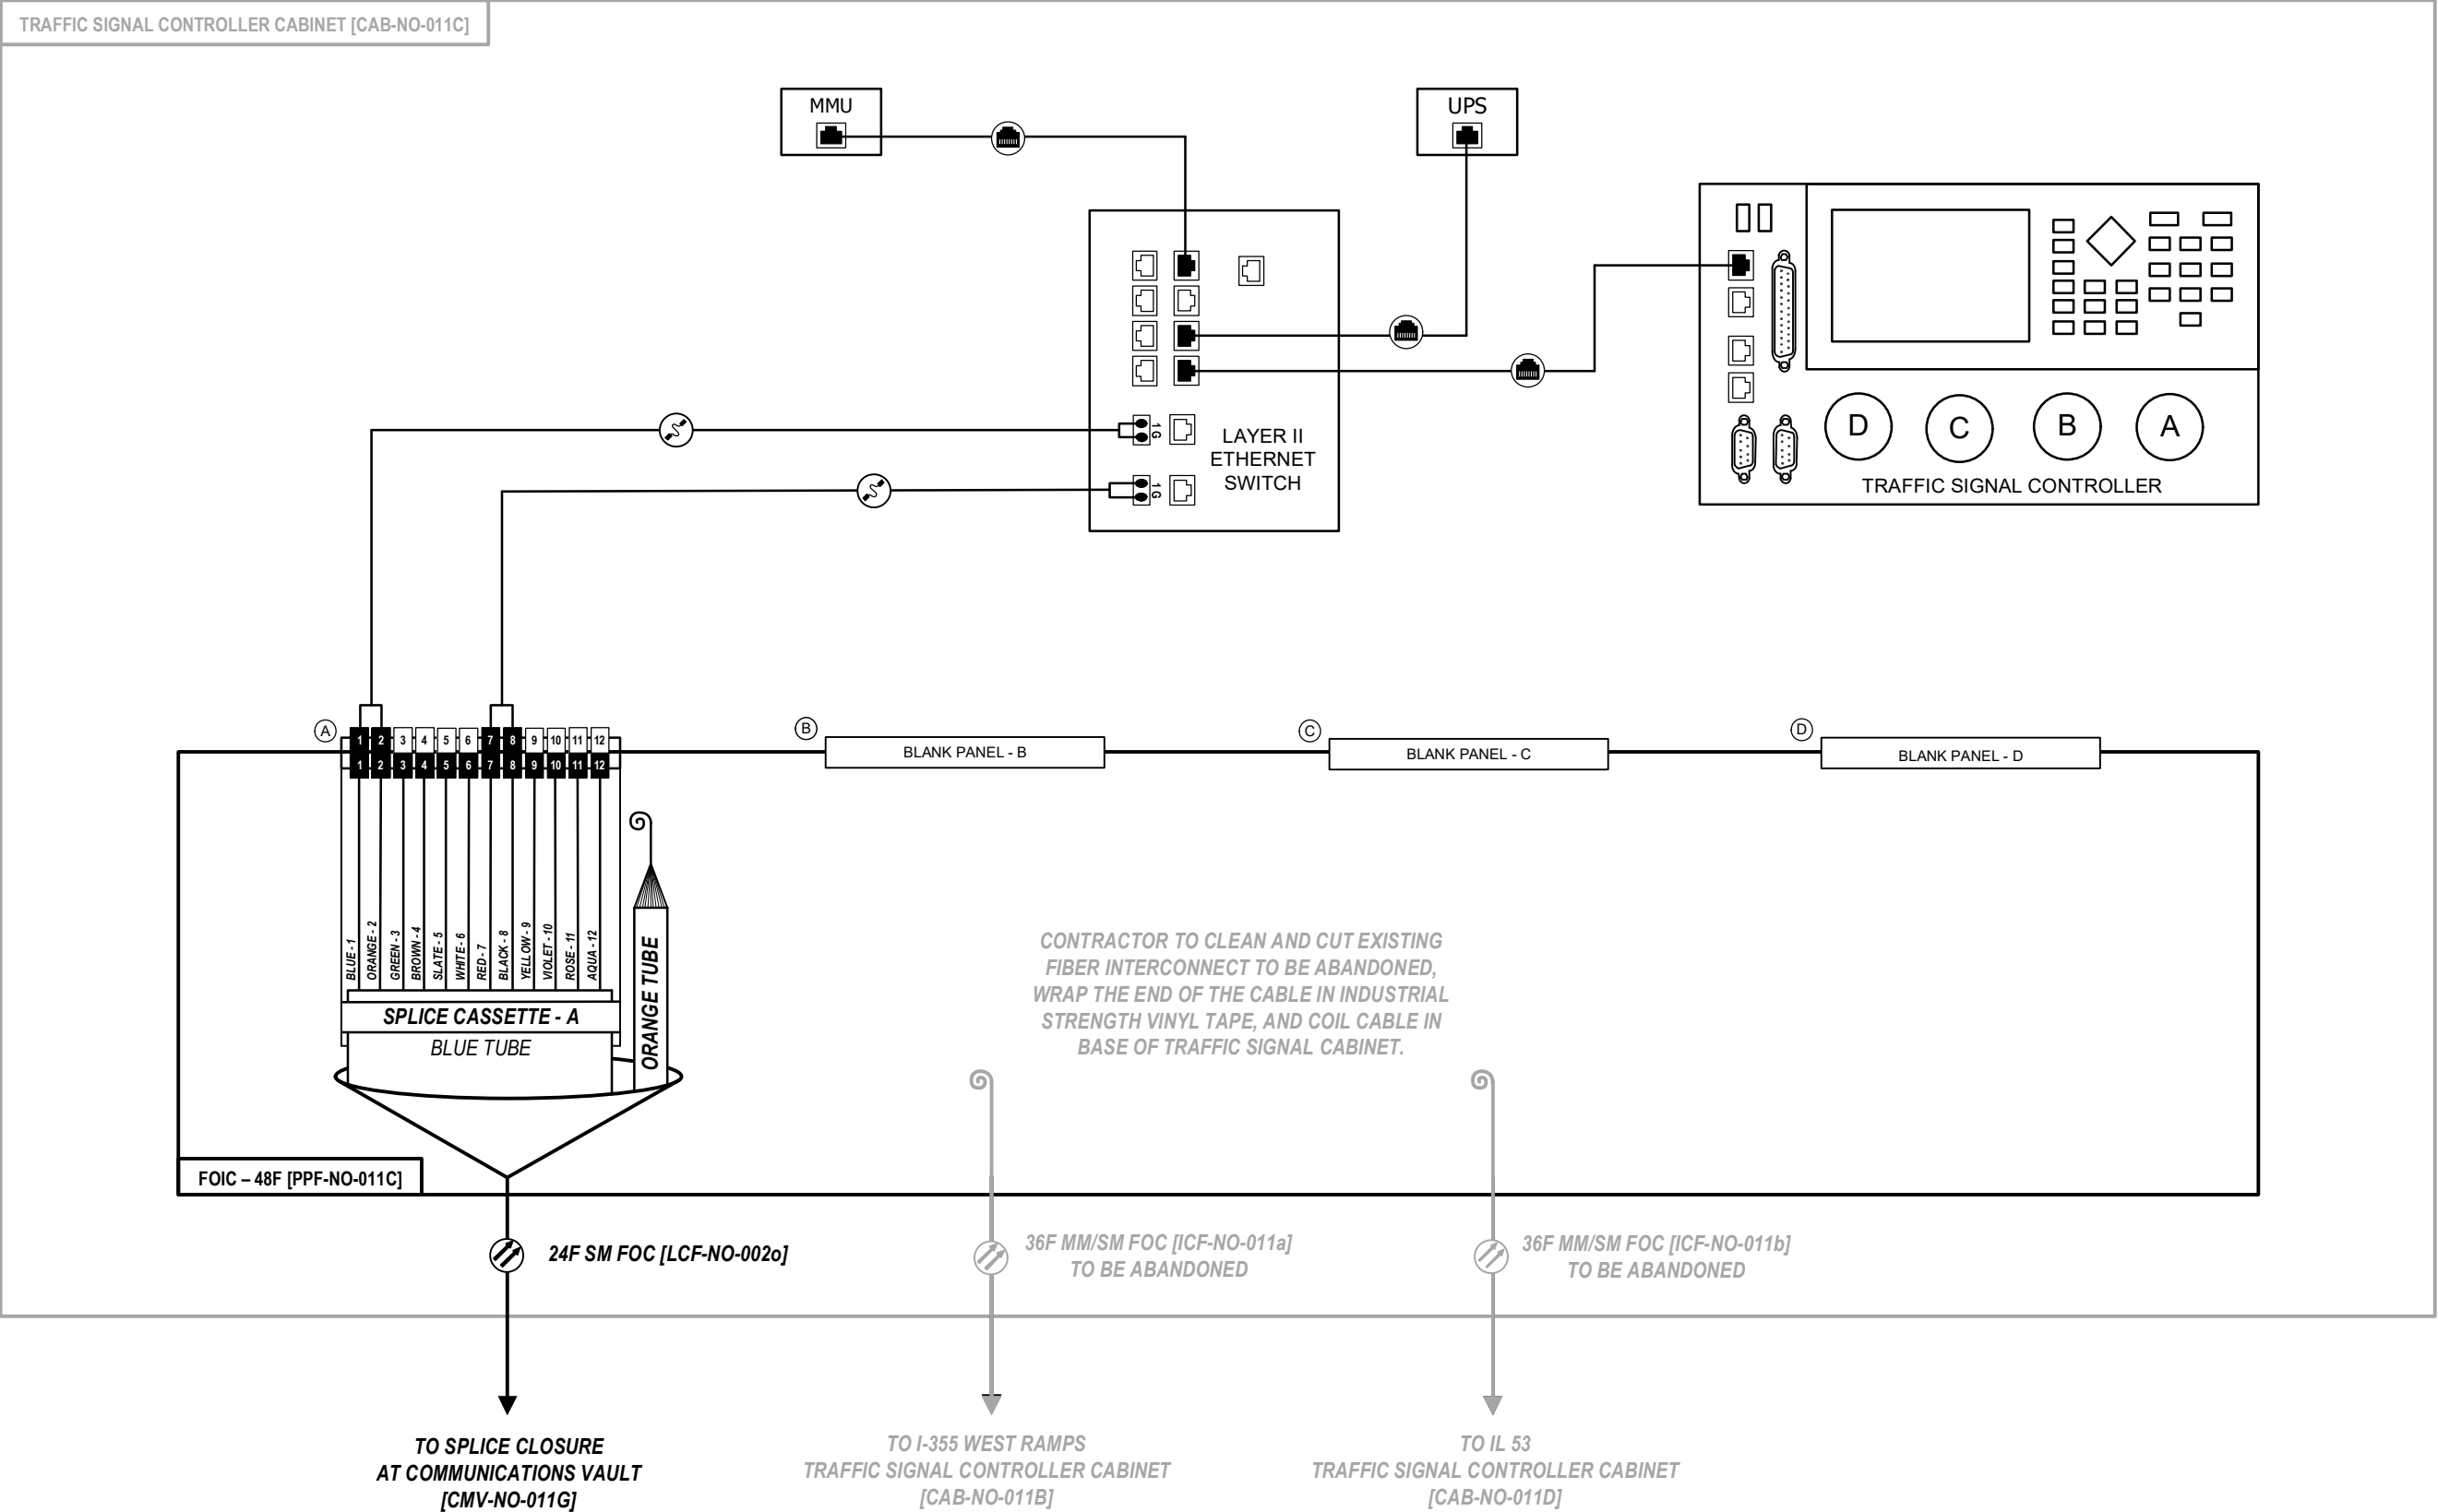

D:\08121-sht-comm-visio

Kimley»Horn

USER NAME =	DESIGNED -	REVISED -
	DRAWN -	REVISED -
PLOT SCALE = N.T.S.	CHECKED -	REVISED -
PLOT DATE =	DATE -	REVISED -


STATE OF ILLINOIS
DEPARTMENT OF TRANSPORTATION

FIBER SPLICING AND CABINET CONNECTION DETAILS
TRAFFIC SIGNAL CONTROLLER CABINET [CAB-NO-011C]

SCALE:	SHEET	OF	SHEETS	STA.	TO STA.
--------	-------	----	--------	------	---------

F.A.P. RTE.	SECTION	COUNTY	TOTAL SHEETS	SHEET NO.
307	2020-263-SUR,SW&TS	DUPAGE	529	414
CONTRACT NO. 62N33				
ILLINOIS FED. AID PROJECT				

IL 64 (NORTH AVENUE) AT
IL 53 (ROHLWING RD / COLUMBINE AVE)

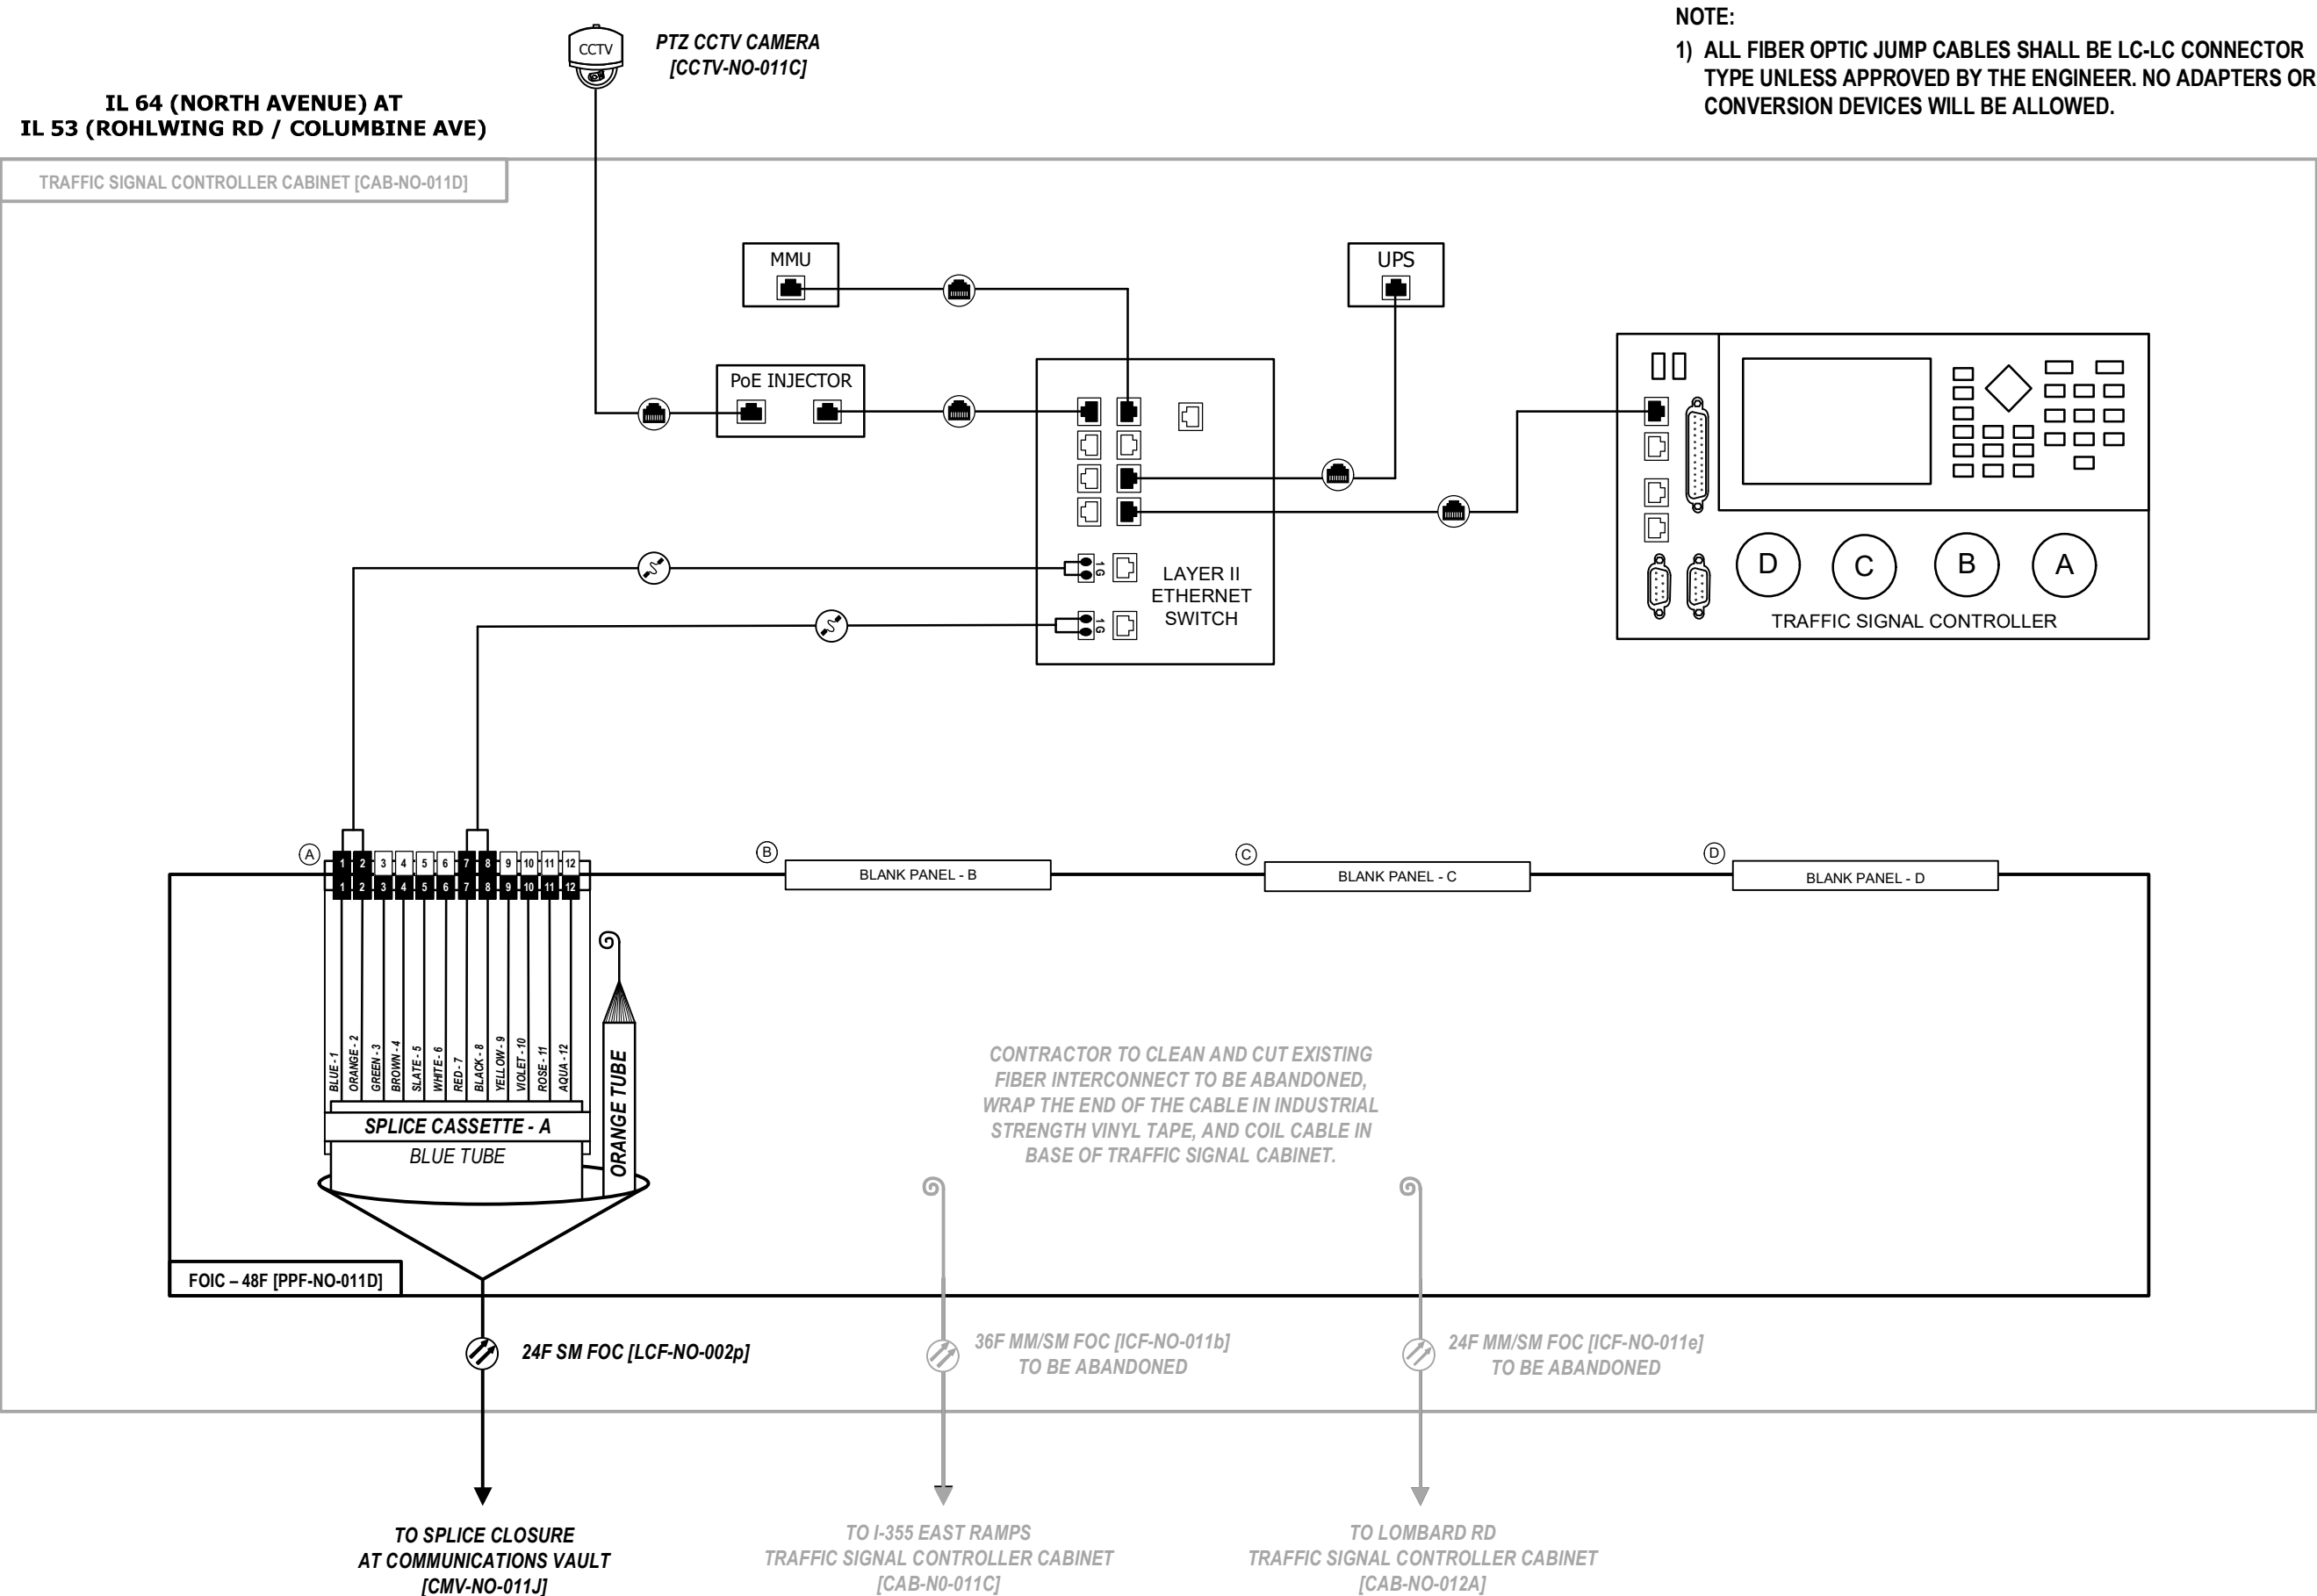

D:\08121-sht-comm-visio

Kimley»Horn

USER NAME =	DESIGNED -	REVISED -
	DRAWN -	REVISED -
PLOT SCALE = N.T.S.	CHECKED -	REVISED -
PLOT DATE =	DATE -	REVISED -

STATE OF ILLINOIS
DEPARTMENT OF TRANSPORTATION


FIBER SPLICING AND CABINET CONNECTION DETAILS TRAFFIC SIGNAL CONTROLLER CABINET [CAB-NO-011D]			
SCALE:	SHEET	OF	SHEETS
STA.	TO STA.		

F.A.P. RTE.	SECTION	COUNTY	TOTAL SHEETS	SHEET NO.
307	2020-263-SUR,SW&TS	DUPAGE	529	415
CONTRACT NO. 62N33				
ILLINOIS				

IL 64 (NORTH AVENUE) AT IL 53

IDOT COMMUNICATIONS NODE CABINET [CAB-NO-011E]

NOTE:
1) ALL FIBER OPTIC JUMP CABLES SHALL BE LC-LC CONNECTOR TYPE UNLESS APPROVED BY THE ENGINEER. NO ADAPTERS OR CONVERSION DEVICES WILL BE ALLOWED.

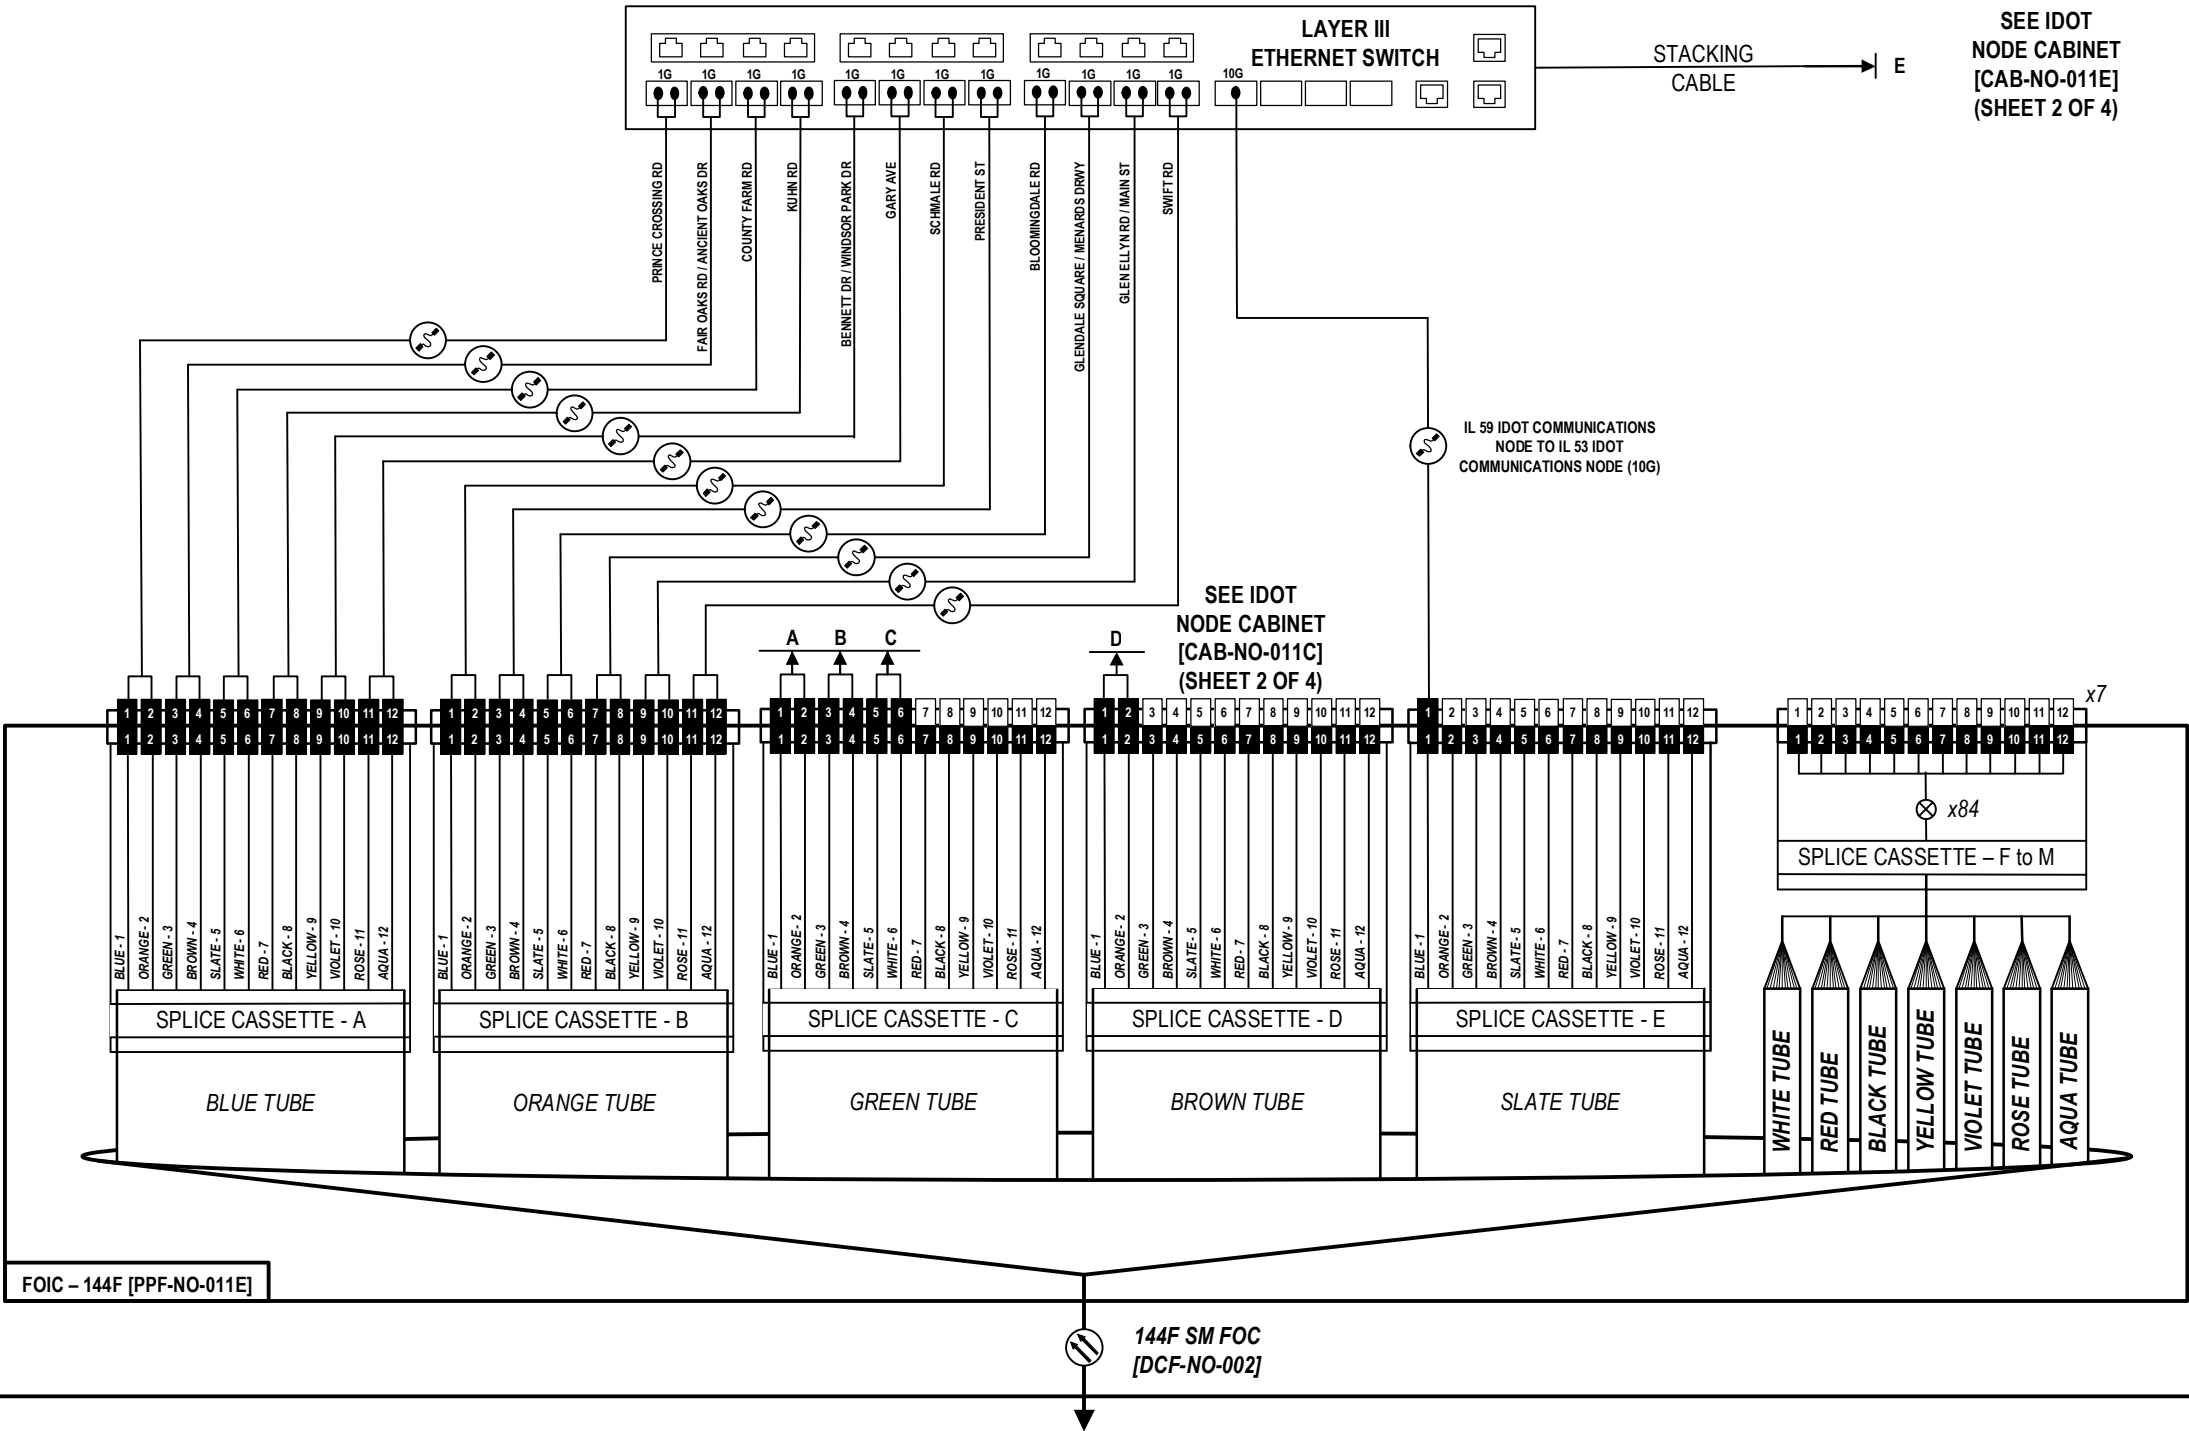


DL08121-sh-comm-visio

IL 64 (NORTH AVENUE) AT IL 53

IDOT COMMUNICATIONS NODE CABINET [CAB-NO-011E]

NOTE:
1) ALL FIBER OPTIC JUMP CABLES SHALL BE LC-LC CONNECTOR TYPE UNLESS APPROVED BY THE ENGINEER. NO ADAPTERS OR CONVERSION DEVICES WILL BE ALLOWED.

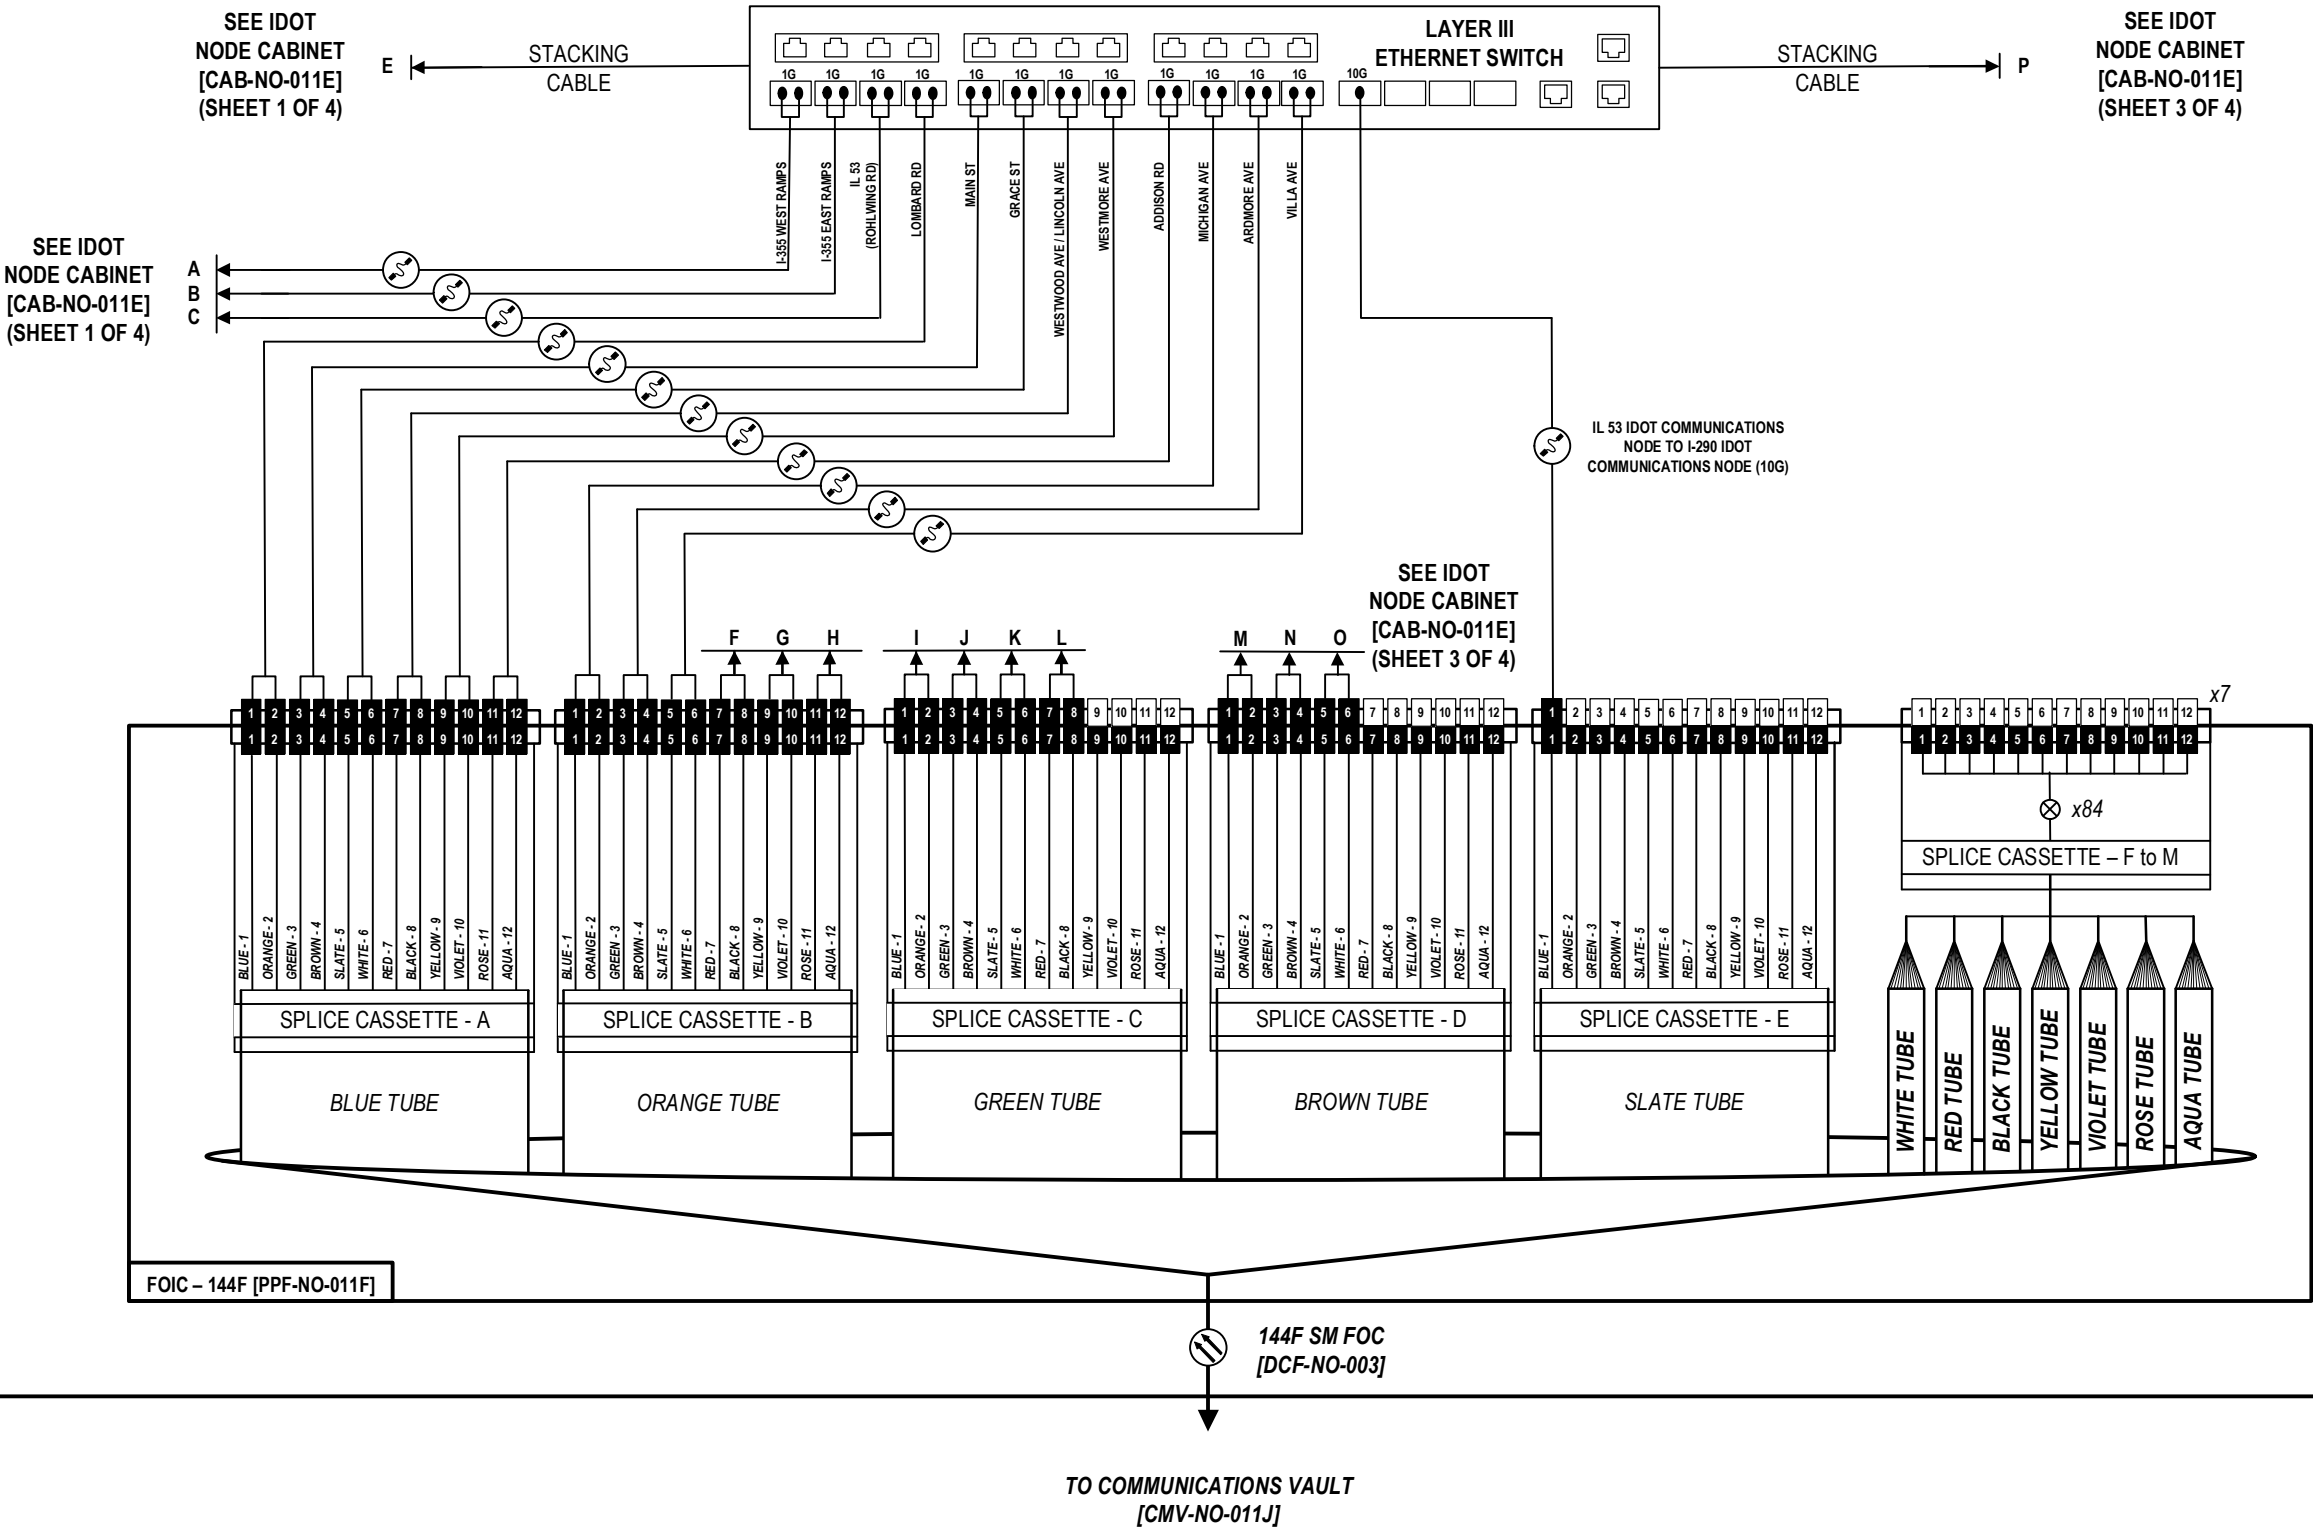

DL08121-shl-comm-visio

Kimley»Horn

USER NAME =	DESIGNED -	REVISED -
	DRAWN -	REVISED -
PLOT SCALE = N.T.S.	CHECKED -	REVISED -
PLOT DATE =	DATE -	REVISED -

STATE OF ILLINOIS
DEPARTMENT OF TRANSPORTATION

FIBER SPLICING AND CABINET CONNECTION DETAILS
IDOT NODE CABINET [CAB-NO-011E] (SHEET 2 OF 4)

SCALE: SHEET OF SHEETS STA. TO STA.

F.A.P. RTE.	SECTION	COUNTY	TOTAL SHEETS	SHEET NO.
307	2020-263-SUR,SW&TS	DUPAGE	529	417
CONTRACT NO. 62N33				
ILLINOIS FED. AID PROJECT				

IL 64 (NORTH AVENUE) AT IL 53


IDOT COMMUNICATIONS NODE CABINET [CAB-NO-011E]

NOTE:
1) ALL FIBER OPTIC JUMP CABLES SHALL BE LC-LC CONNECTOR TYPE UNLESS APPROVED BY THE ENGINEER. NO ADAPTERS OR CONVERSION DEVICES WILL BE ALLOWED.

SEE IDOT
NODE CABINET
[CAB-NO-011E]
(SHEET 2 OF 4)

SEE IDOT
NODE CABINET
[CAB-NO-011E]
(SHEET 2 OF 4)

SEE IDOT
NODE CABINET
[CAB-NO-011E]
(SHEET 2 OF 4)

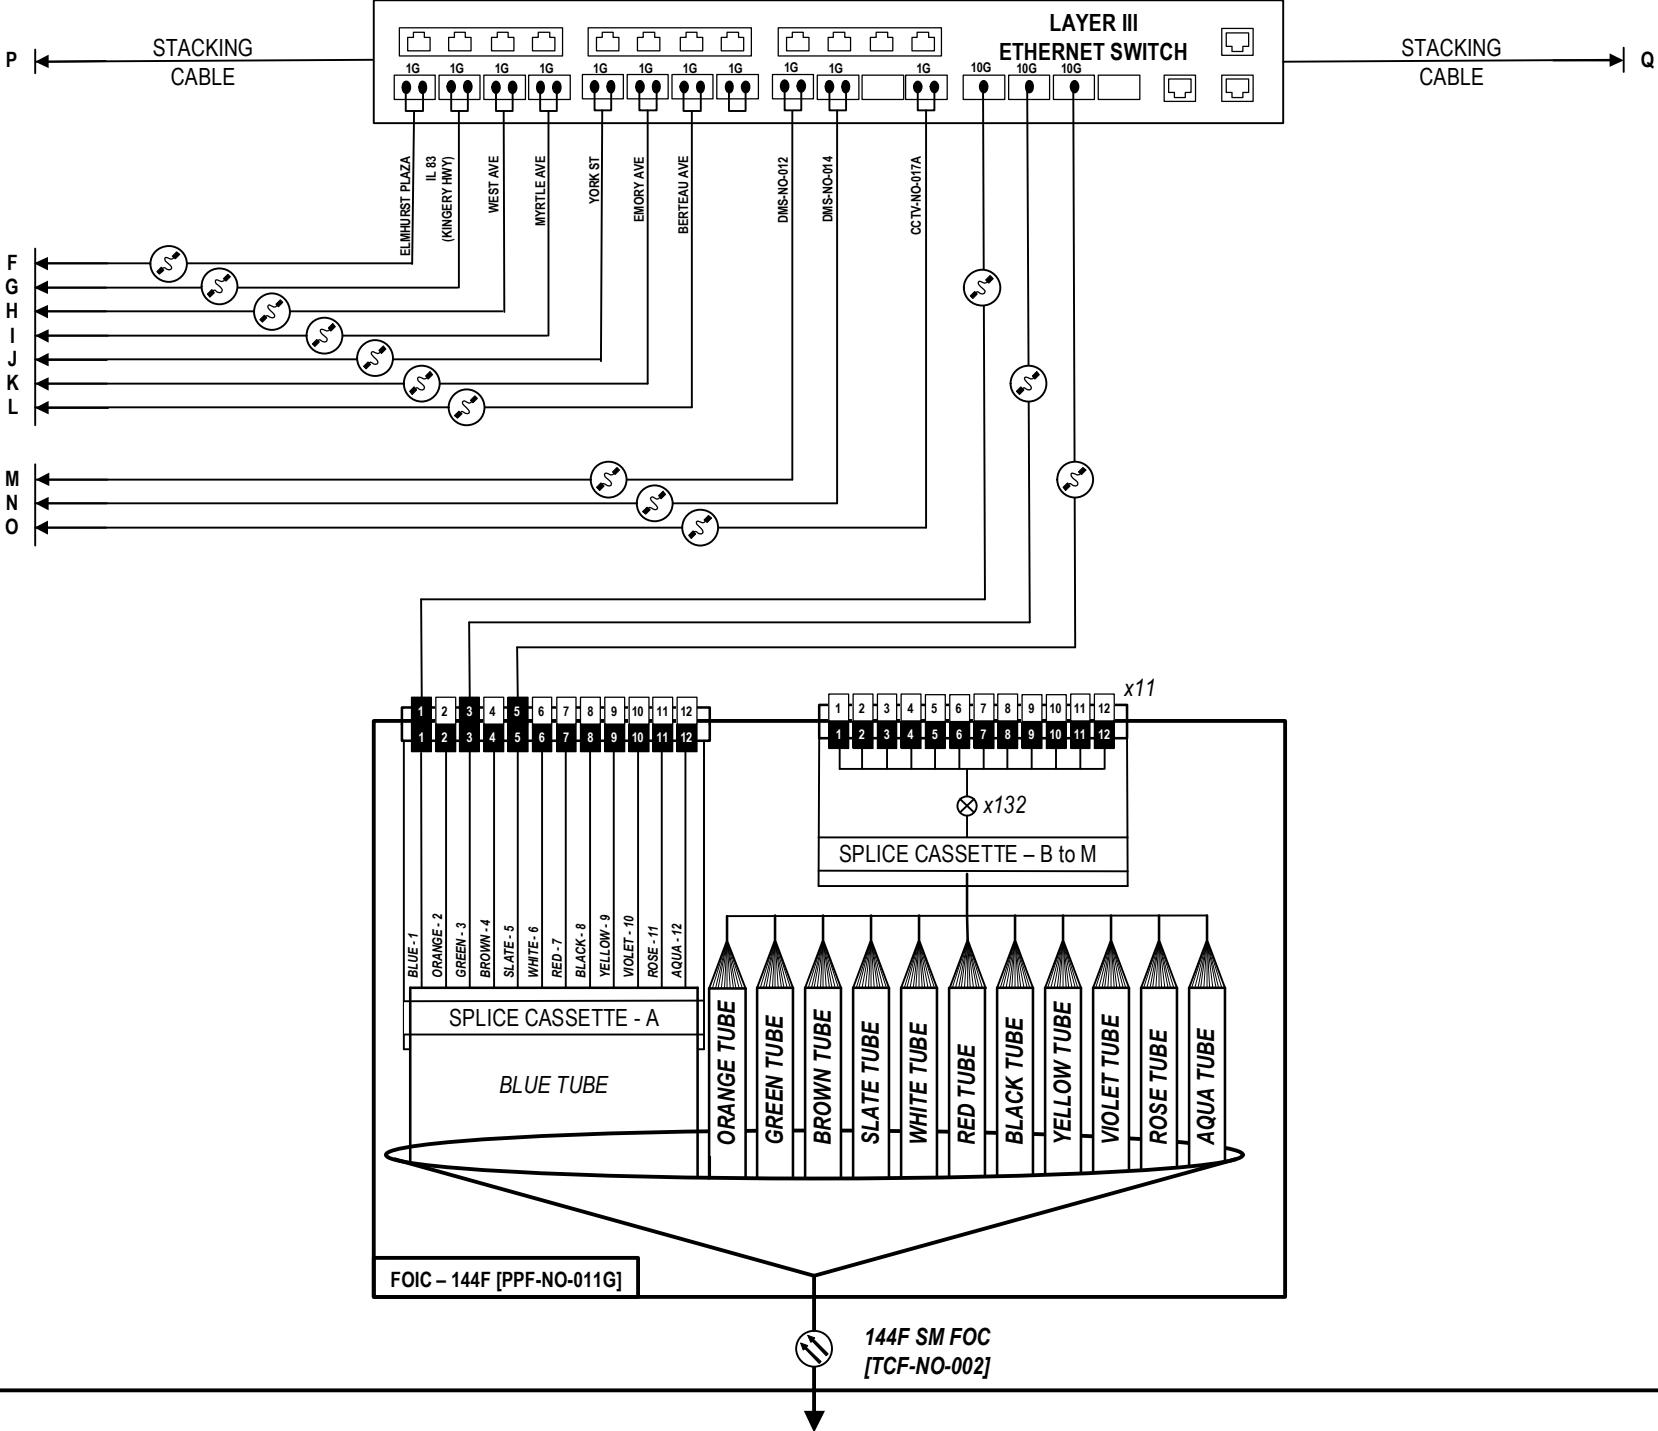

SEE IDOT
NODE CABINET
[CAB-NO-011E]
(SHEET 4 OF 4)

TO COMMUNICATIONS VAULT
[CMV-NO-011J]

DL08121-sh-comm-visio



USER NAME =	DESIGNED -	REVISED -
	DRAWN -	REVISED -
PLOT SCALE = N.T.S.	CHECKED -	REVISED -
PLOT DATE =	DATE -	REVISED -

STATE OF ILLINOIS
DEPARTMENT OF TRANSPORTATION


FIBER SPLICING AND CABINET CONNECTION DETAILS
IDOT NODE CABINET [CAB-NO-011E] (SHEET 3 OF 4)

SCALE: SHEET OF SHEETS STA. TO STA.


F.A.P. RTE.	SECTION	COUNTY	TOTAL SHEETS	SHEET NO.
307	2020-263-SUR,SW&TS	DUPAGE	529	418
CONTRACT NO. 62N33				
ILLINOIS FED. AID PROJECT				

IDOT COMMUNICATIONS NODE CABINET [CAB-NO-011E]

1) ALL FIBER OPTIC JUMP CABLES SHALL BE LC-LC CONNECTOR TYPE UNLESS APPROVED BY THE ENGINEER. NO ADAPTERS OR CONVERSION DEVICES WILL BE ALLOWED.

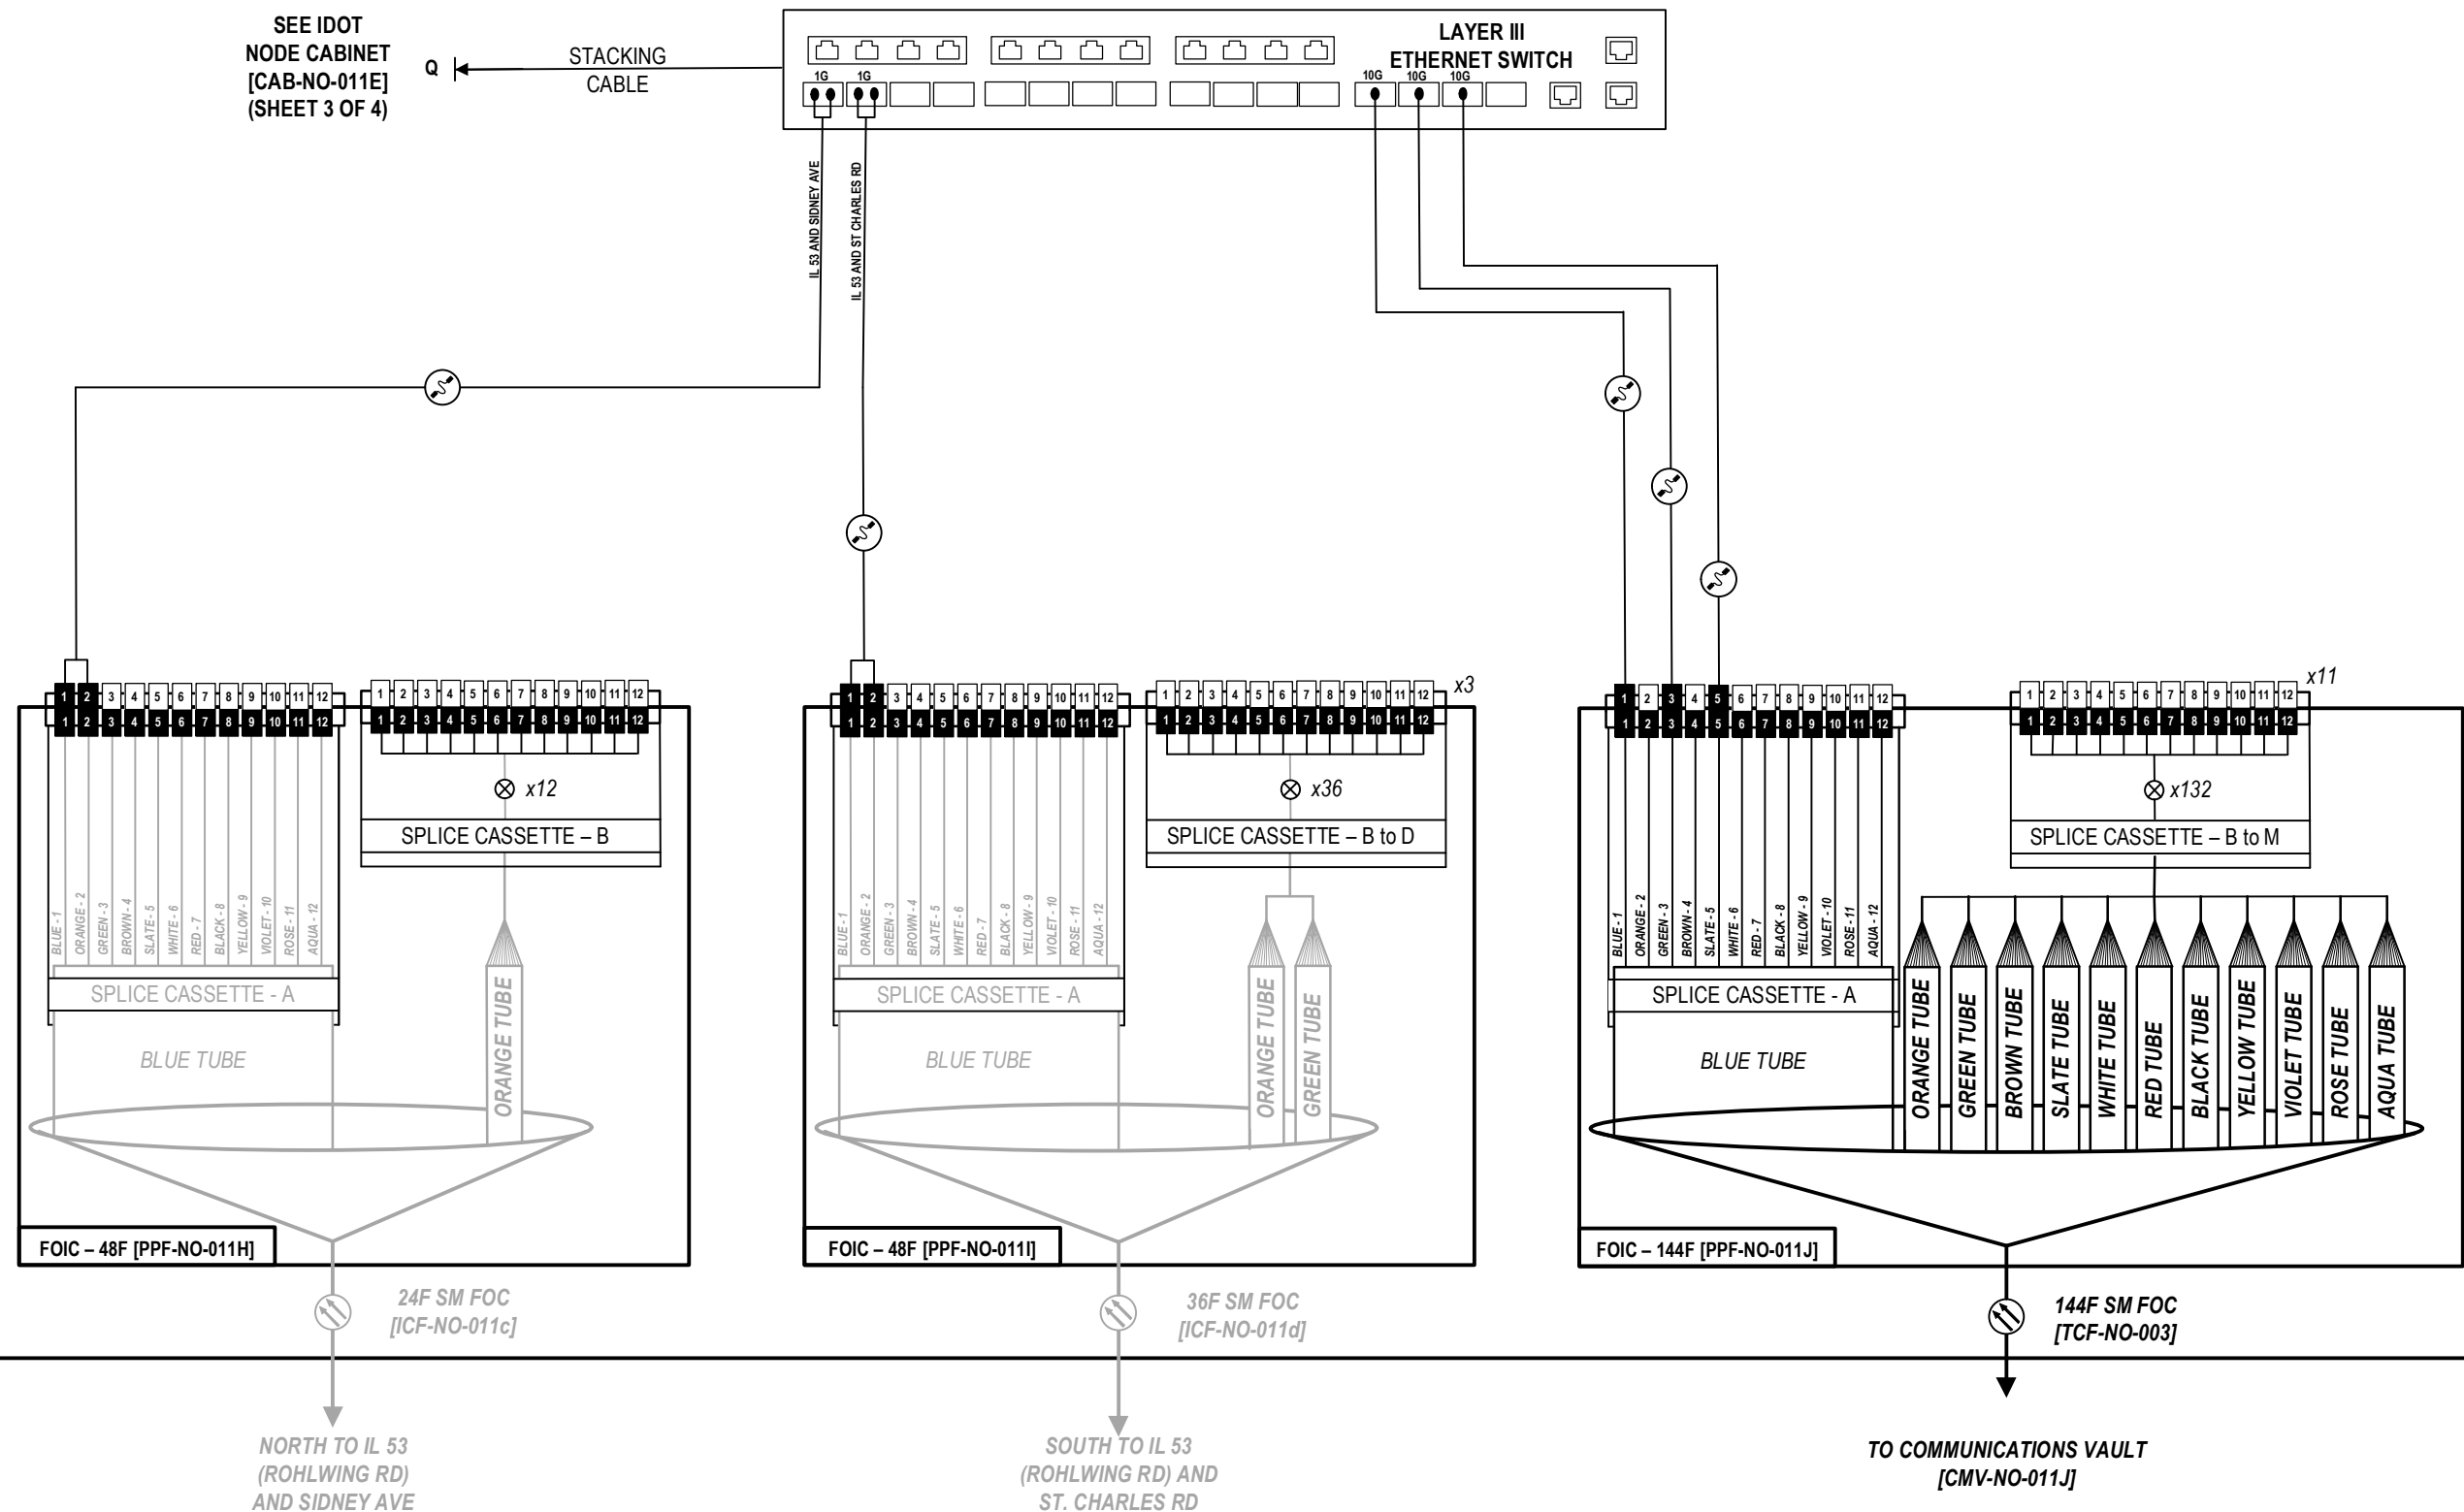

IL 64 (NORTH AVENUE) WESTBOUND DMS
BETWEEN IL 53 AND LOMBARD RD

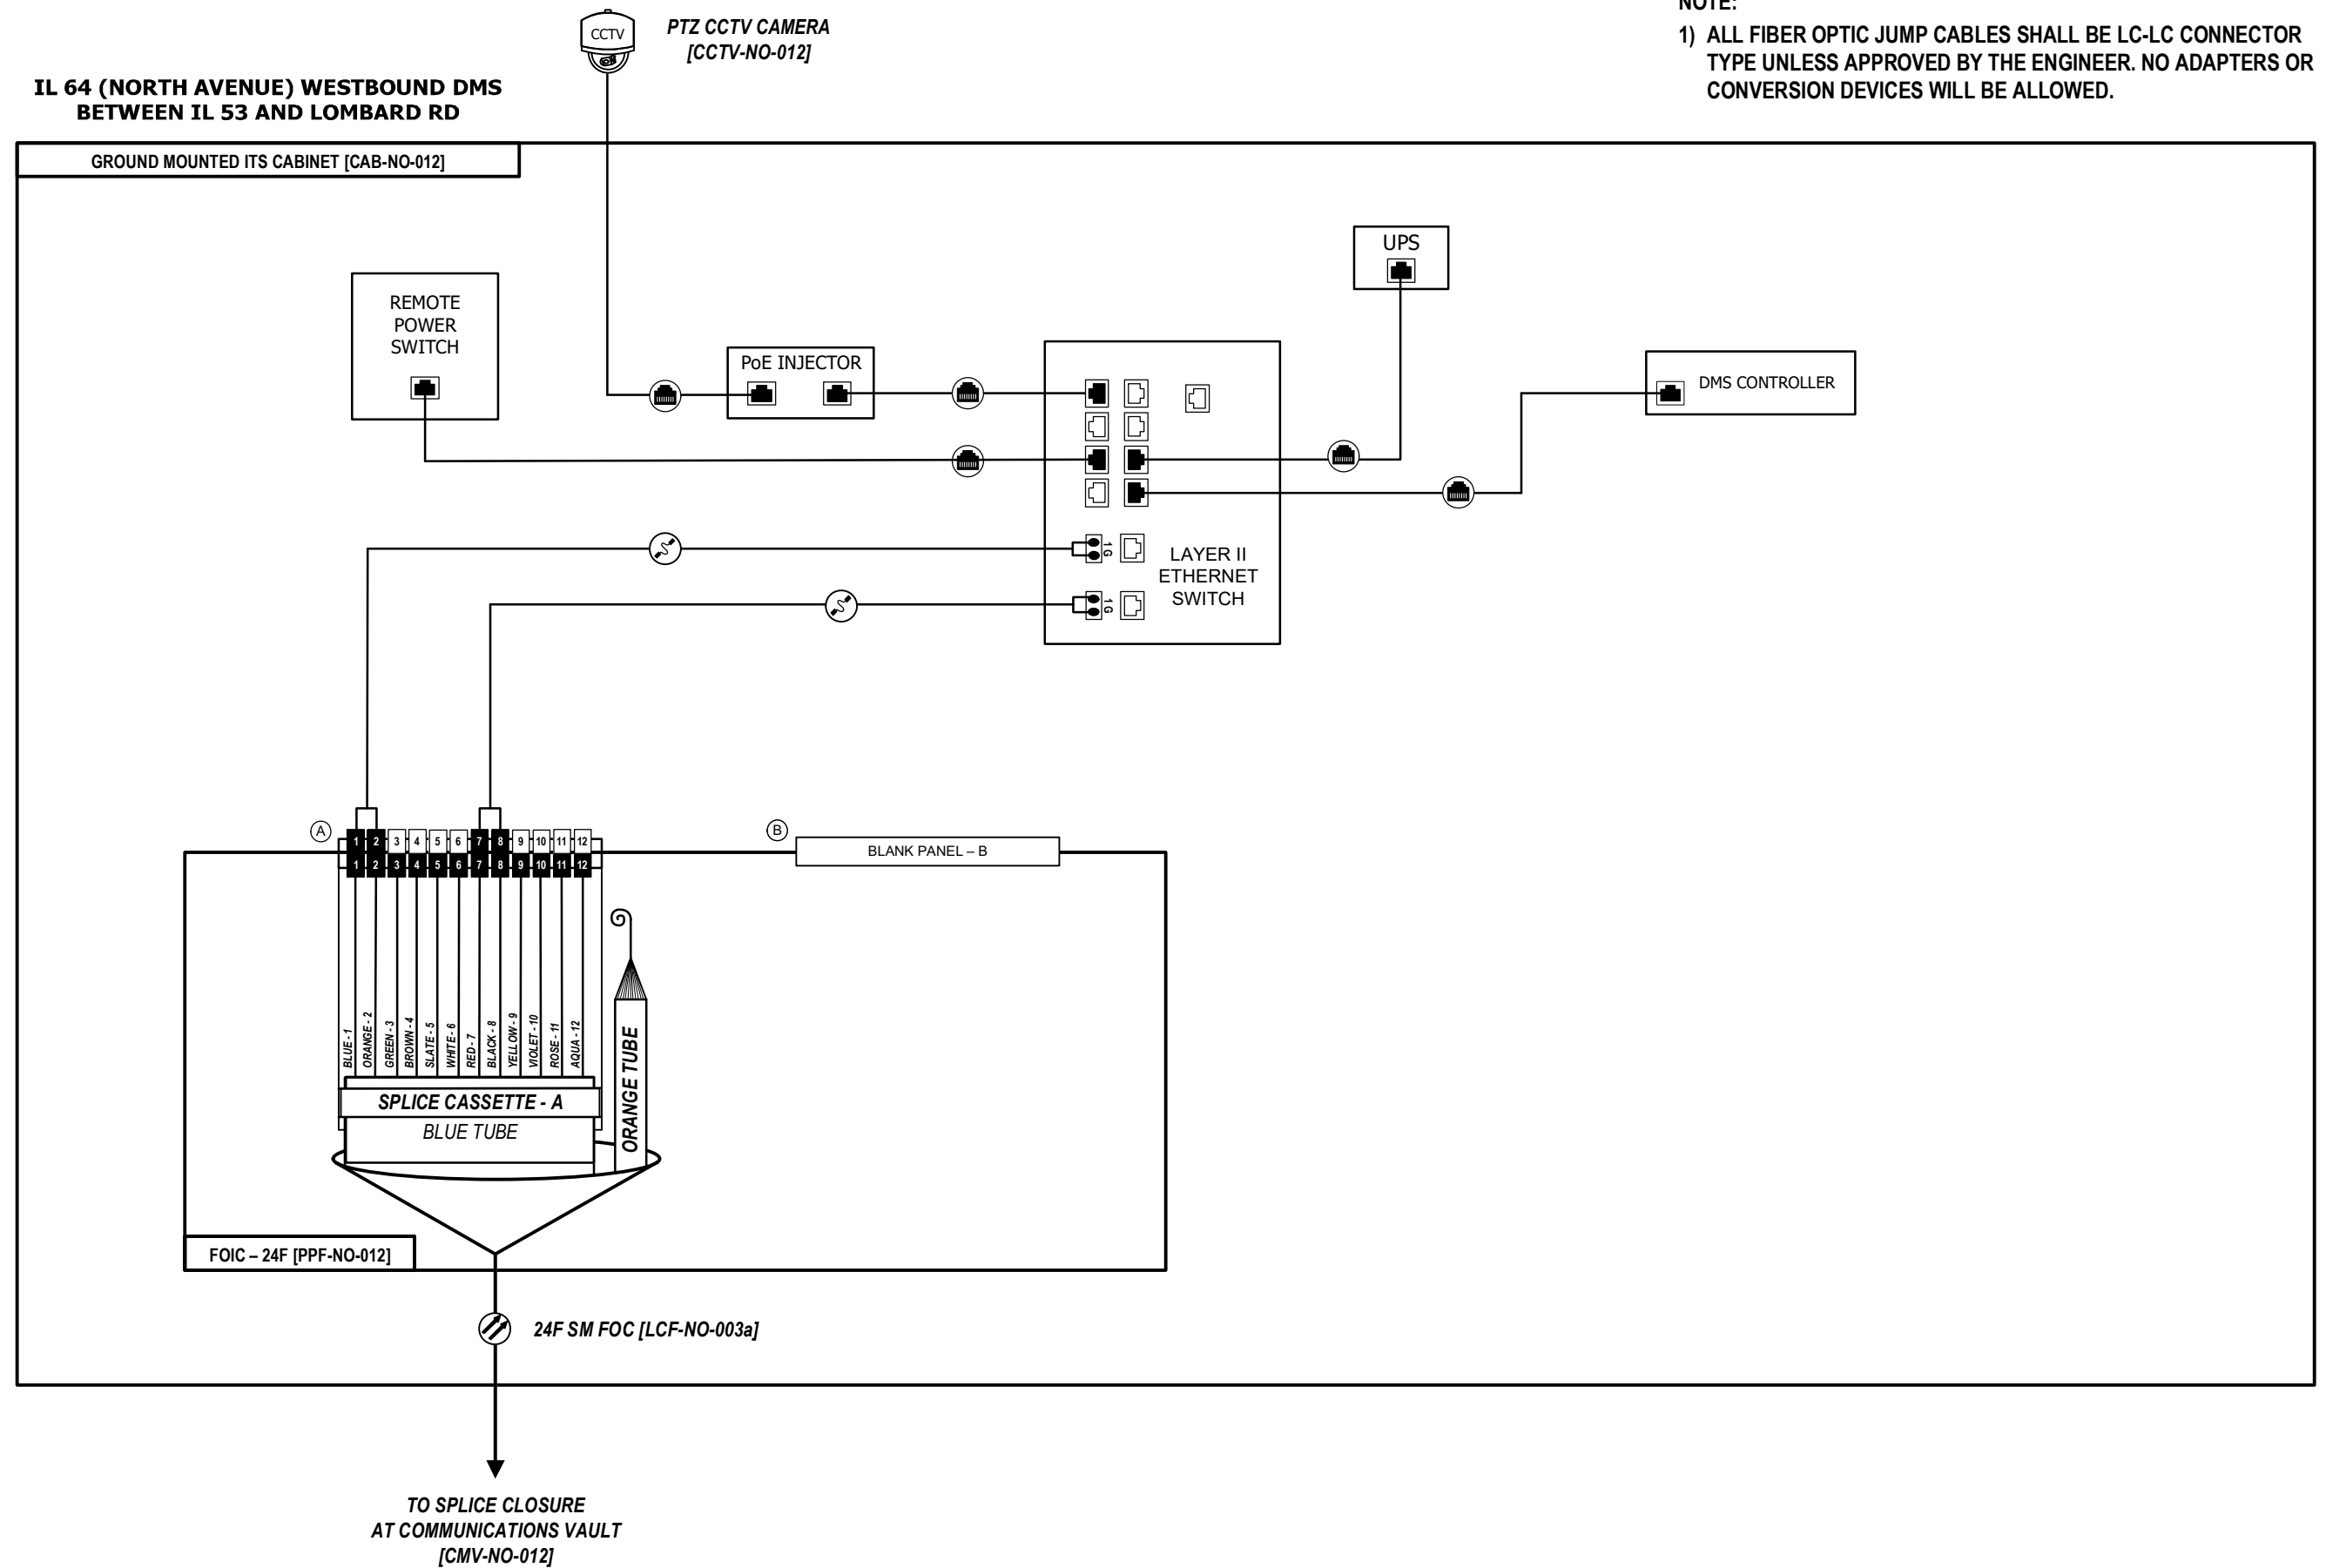

NOTE:
1) ALL FIBER OPTIC JUMP CABLES SHALL BE LC-LC CONNECTOR
TYPE UNLESS APPROVED BY THE ENGINEER. NO ADAPTERS OR
CONVERSION DEVICES WILL BE ALLOWED.

D:\08121-sht-comm-visio

Kimley»Horn

USER NAME =	DESIGNED -	REVISED -
	DRAWN -	REVISED -
PLOT SCALE = N.T.S.	CHECKED -	REVISED -
PLOT DATE =	DATE -	REVISED -


STATE OF ILLINOIS
DEPARTMENT OF TRANSPORTATION

FIBER SPLICING AND CABINET CONNECTION DETAILS
GROUND MOUNTED ITS CABINET [CAB-NO-012]

SCALE:	SHEET	OF	SHEETS	STA.	TO STA.
--------	-------	----	--------	------	---------

F.A.P. RTE.	SECTION	COUNTY	TOTAL SHEETS	SHEET NO.
307	2020-263-SUR,SW&TS	DUPAGE	529	420
CONTRACT NO. 62N33				
ILLINOIS				

IL 64 (NORTH AVENUE)
AT LOMBARD RD

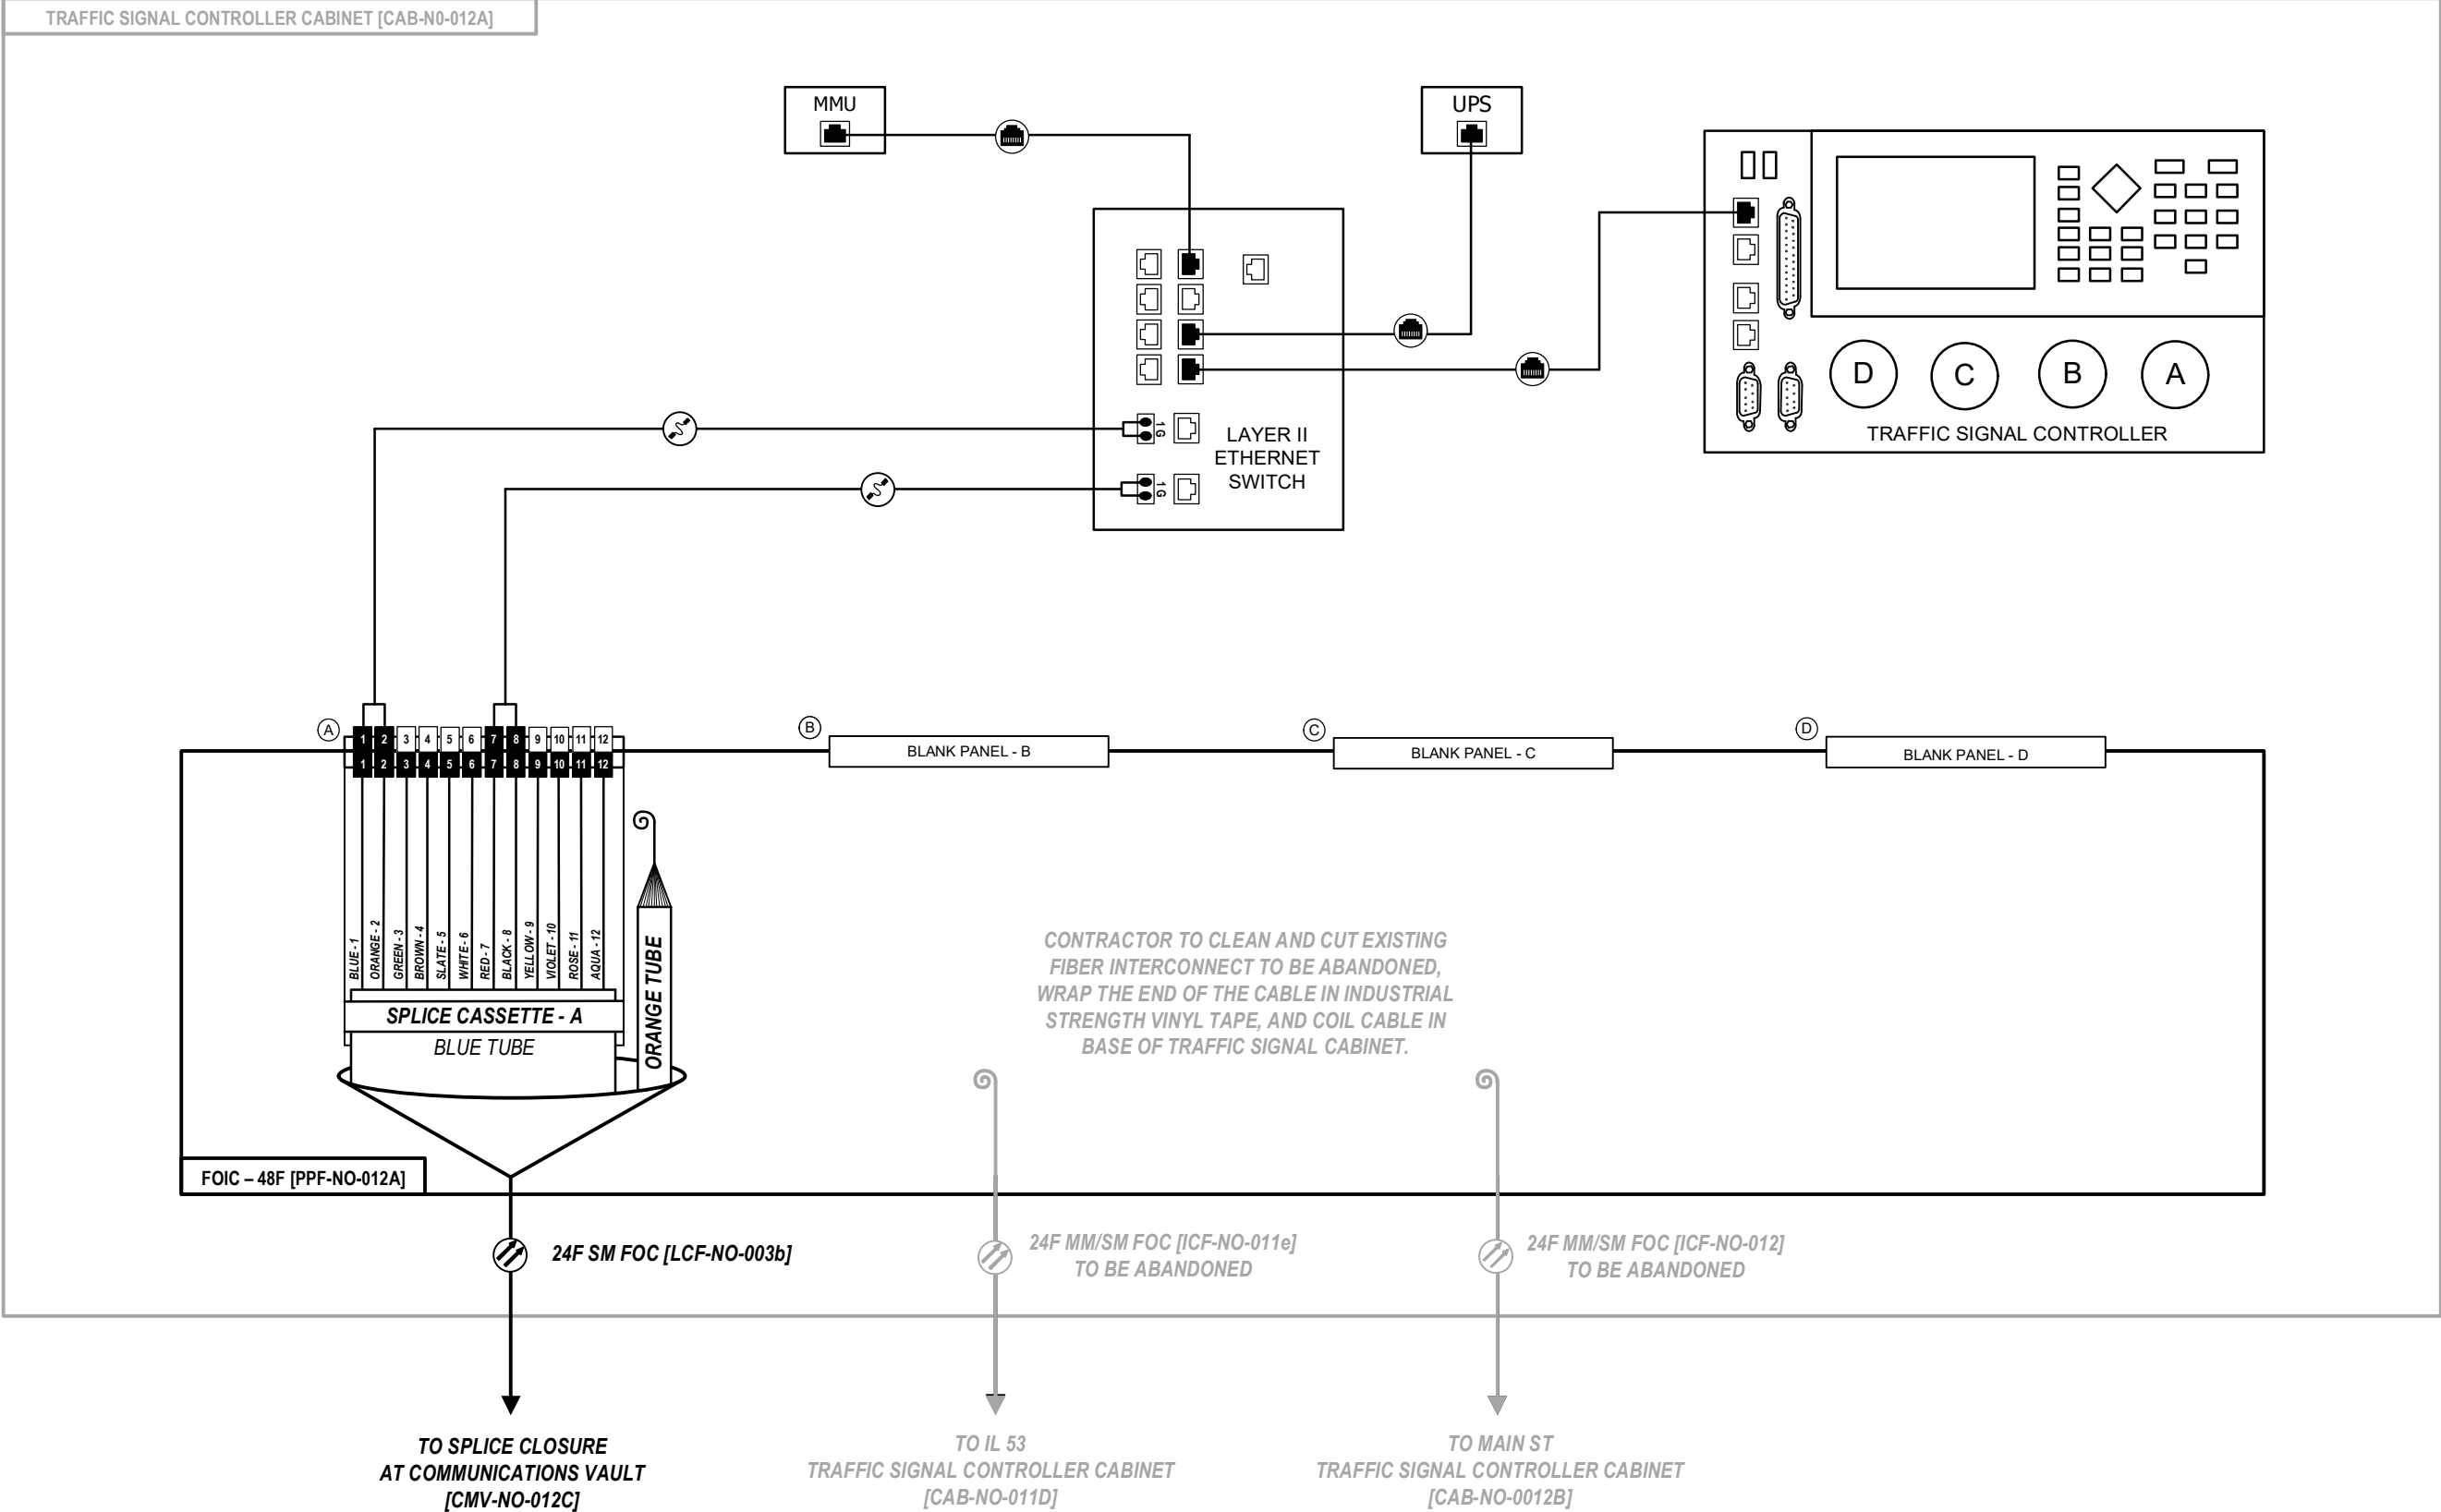

NOTE:
1) ALL FIBER OPTIC JUMP CABLES SHALL BE LC-LC CONNECTOR TYPE UNLESS APPROVED BY THE ENGINEER. NO ADAPTERS OR CONVERSION DEVICES WILL BE ALLOWED.

D:\08121-sht-comm-visio

Kimley»Horn


USER NAME =	DESIGNED -	REVISED -
	DRAWN -	REVISED -
PLOT SCALE = N.T.S.	CHECKED -	REVISED -
PLOT DATE =	DATE -	REVISED -

STATE OF ILLINOIS
DEPARTMENT OF TRANSPORTATION

FIBER SPLICING AND CABINET CONNECTION DETAILS
TRAFFIC SIGNAL CONTROLLER CABINET [CAB-NO-012A]

SCALE:	SHEET	OF	SHEETS	STA.	TO STA.
--------	-------	----	--------	------	---------

F.A.P. RTE.	SECTION	COUNTY	TOTAL SHEETS	SHEET NO.
307	2020-263-SUR,SW&TS	DUPAGE	529	421
CONTRACT NO. 62N33				
ILLINOIS				

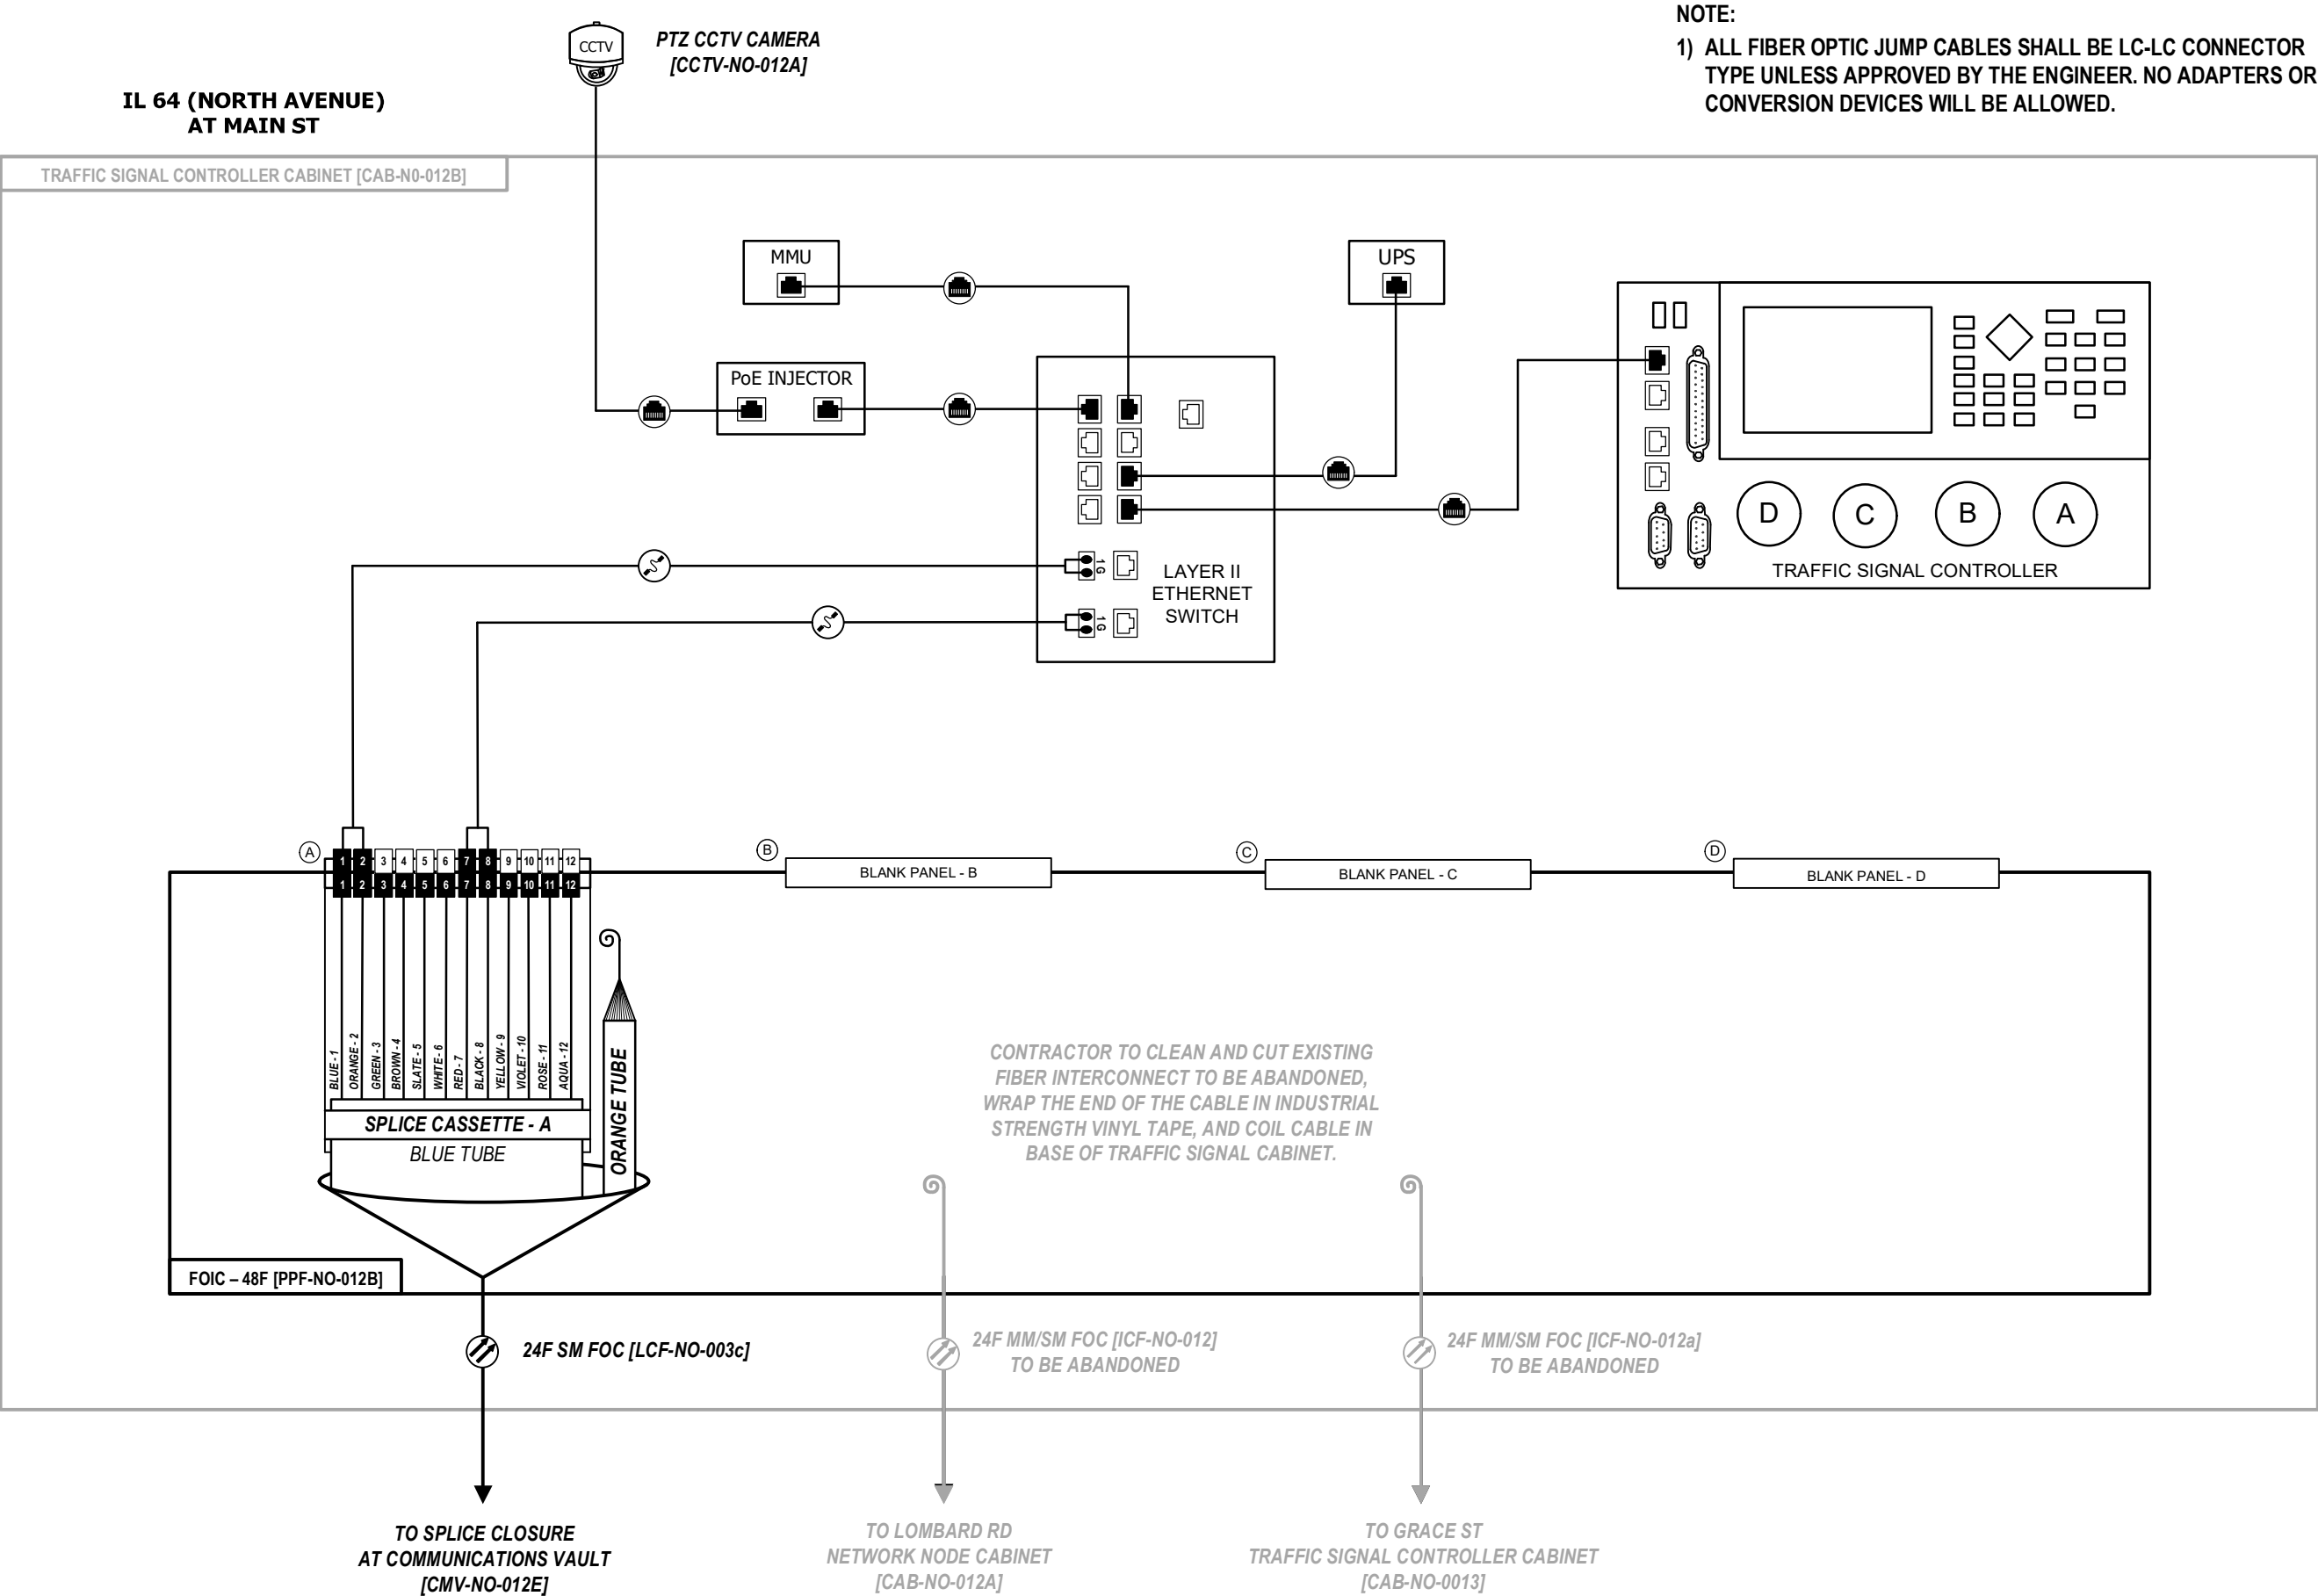

D:\08121-sht-comm-visio

Kimley»Horn

USER NAME =	DESIGNED -	REVISED -
	DRAWN -	REVISED -
PLOT SCALE = N.T.S.	CHECKED -	REVISED -
PLOT DATE =	DATE -	REVISED -

STATE OF ILLINOIS
DEPARTMENT OF TRANSPORTATION


FIBER SPLICING AND CABINET CONNECTION DETAILS
TRAFFIC SIGNAL CONTROLLER CABINET [CAB-NO-012B]

SCALE: SHEET OF SHEETS STA. TO STA.

F.A.P. RTE.	SECTION	COUNTY	TOTAL SHEETS	SHEET NO.
307	2020-263-SUR,SW&TS	DUPAGE	529	422
CONTRACT NO. 62N33				
ILLINOIS FED. AID PROJECT				

IL 64 (NORTH AVENUE)
AT GRACE ST

TRAFFIC SIGNAL CONTROLLER CABINET [CAB-NO-013]

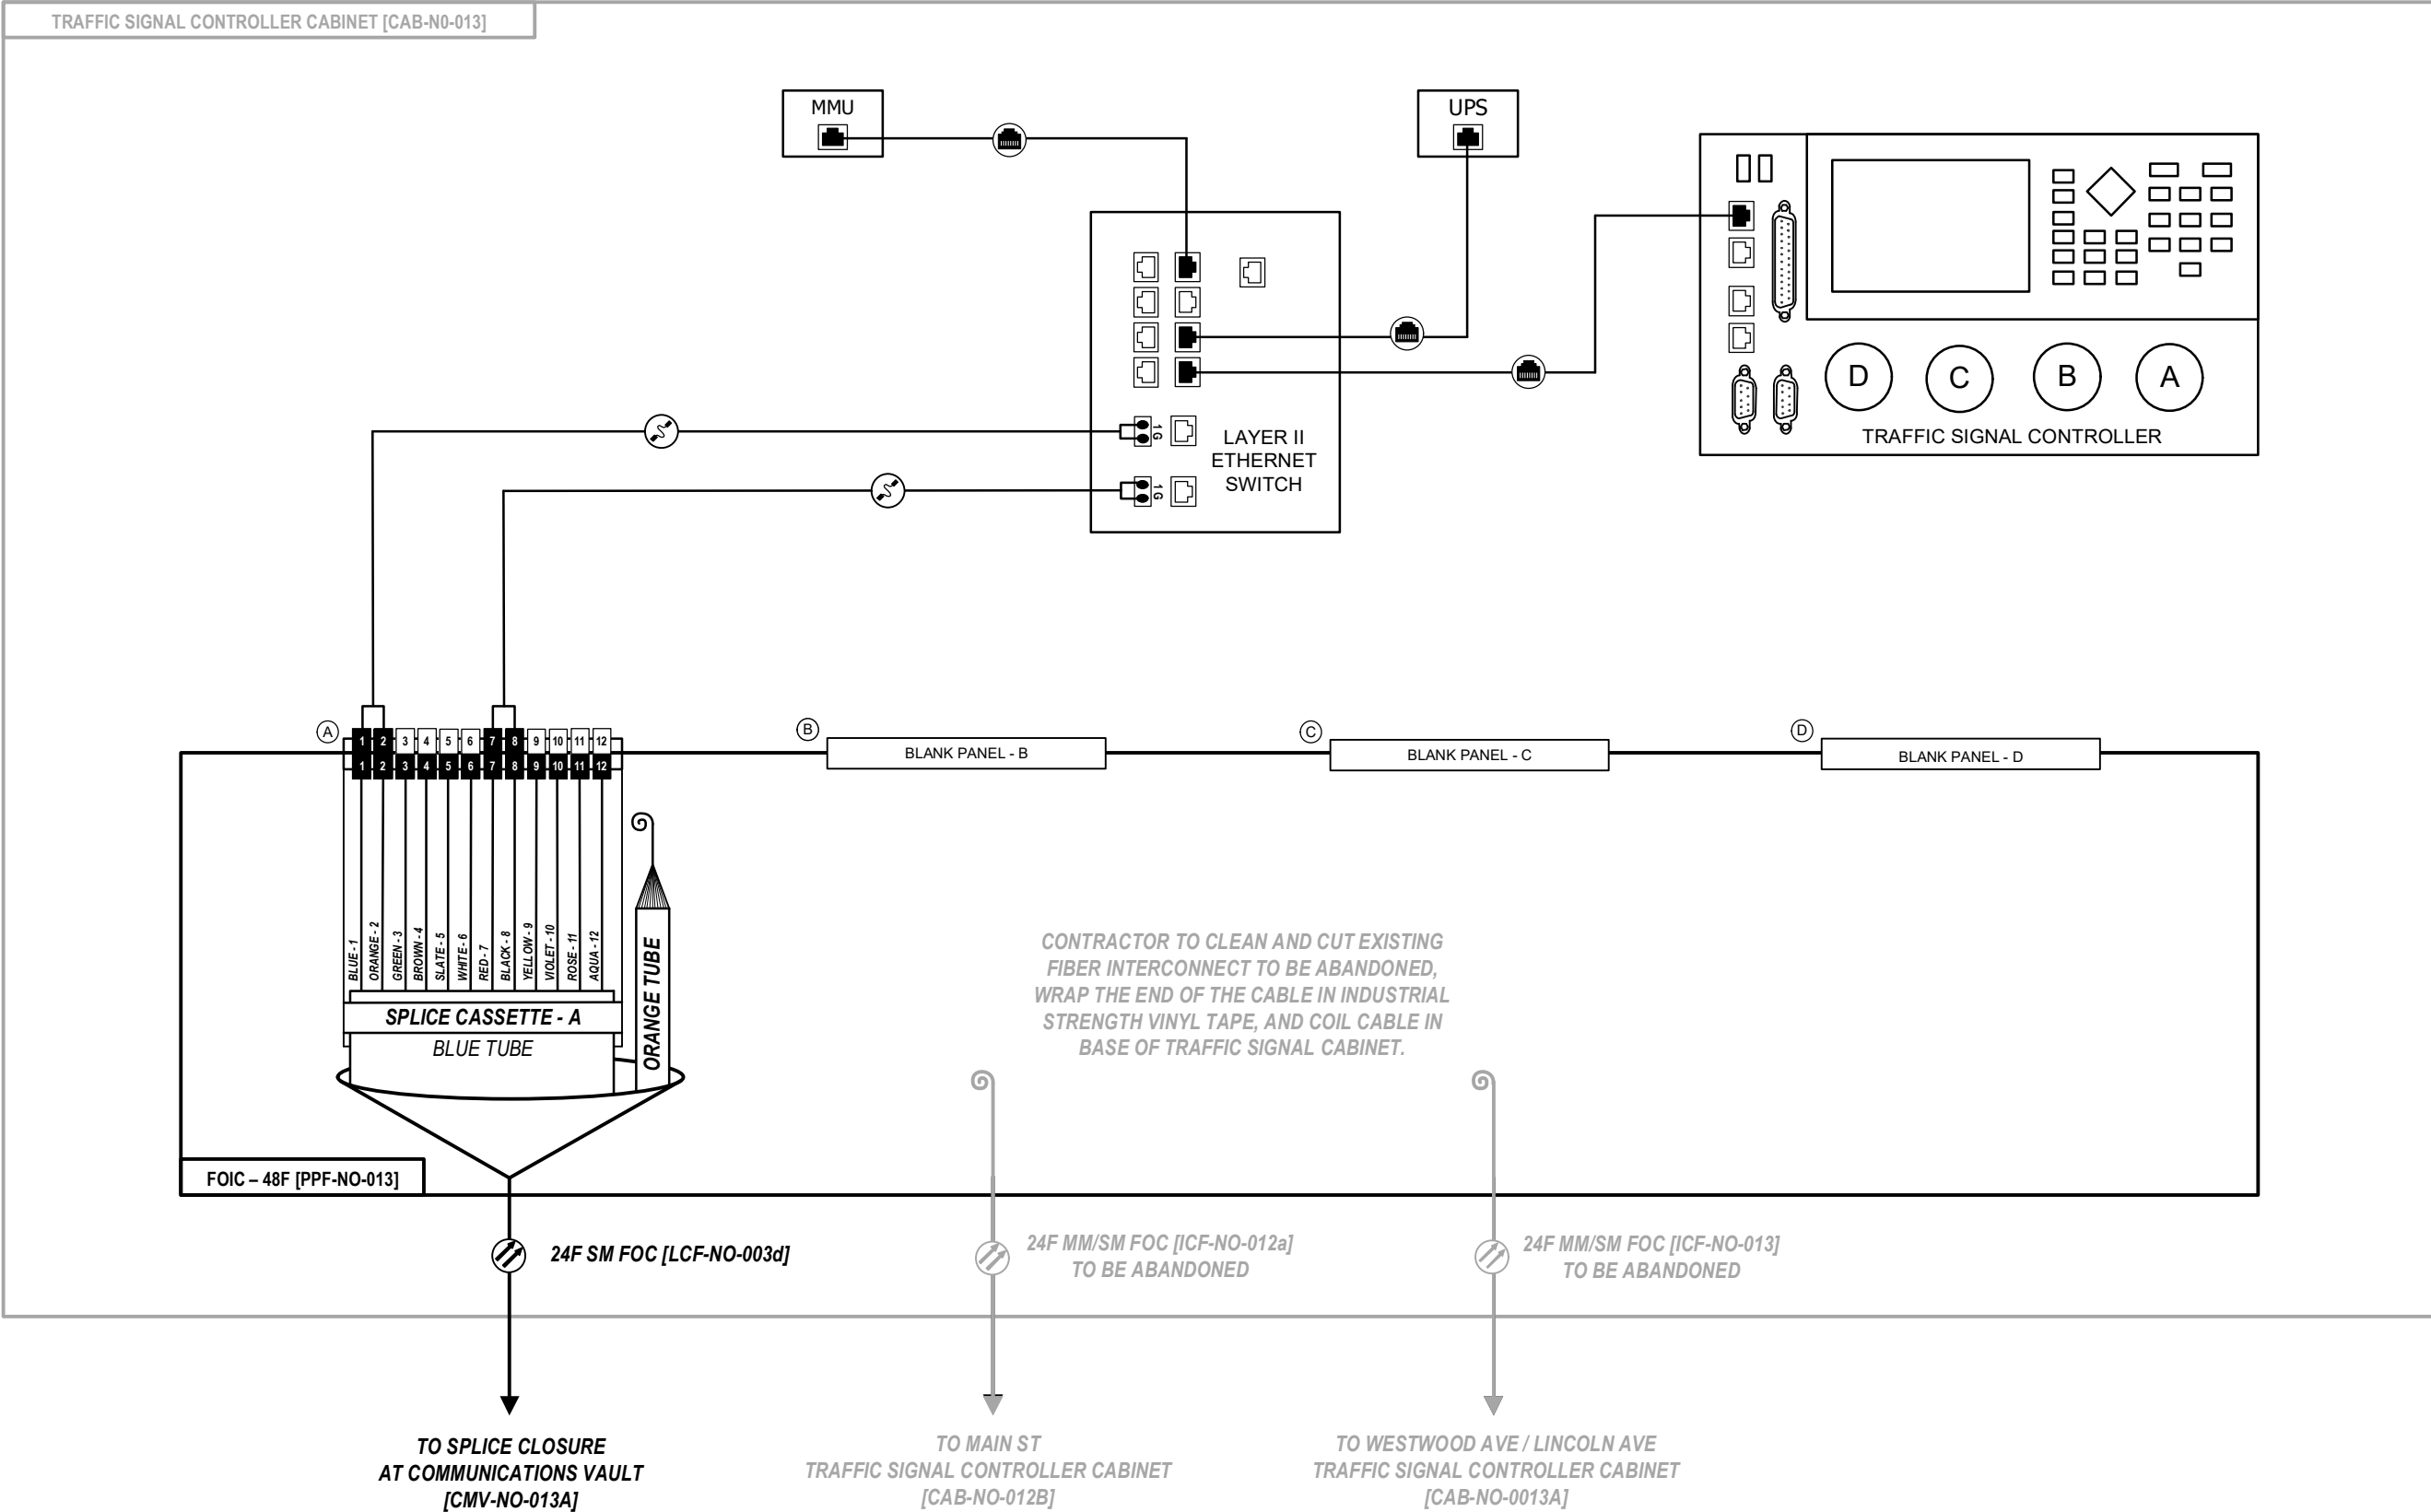

D:\08121-sht-comm-visio

Kimley»Horn

USER NAME =	DESIGNED -	REVISED -
	DRAWN -	REVISED -
PLOT SCALE = N.T.S.	CHECKED -	REVISED -
PLOT DATE =	DATE -	REVISED -

STATE OF ILLINOIS
DEPARTMENT OF TRANSPORTATION


FIBER SPLICING AND CABINET CONNECTION DETAILS
TRAFFIC SIGNAL CONTROLLER CABINET [CAB-NO-013]

SCALE: SHEET OF SHEETS STA. TO STA.

F.A.P. RTE.	SECTION	COUNTY	TOTAL SHEETS	SHEET NO.
307	2020-263-SUR,SW&TS	DUPAGE	529	423
CONTRACT NO. 62N33				
ILLINOIS FED. AID PROJECT				

IL 64 (NORTH AVENUE)
AT WESTWOOD AVE / LINCOLN AVE

TRAFFIC SIGNAL CONTROLLER CABINET [CAB-NO-013A]

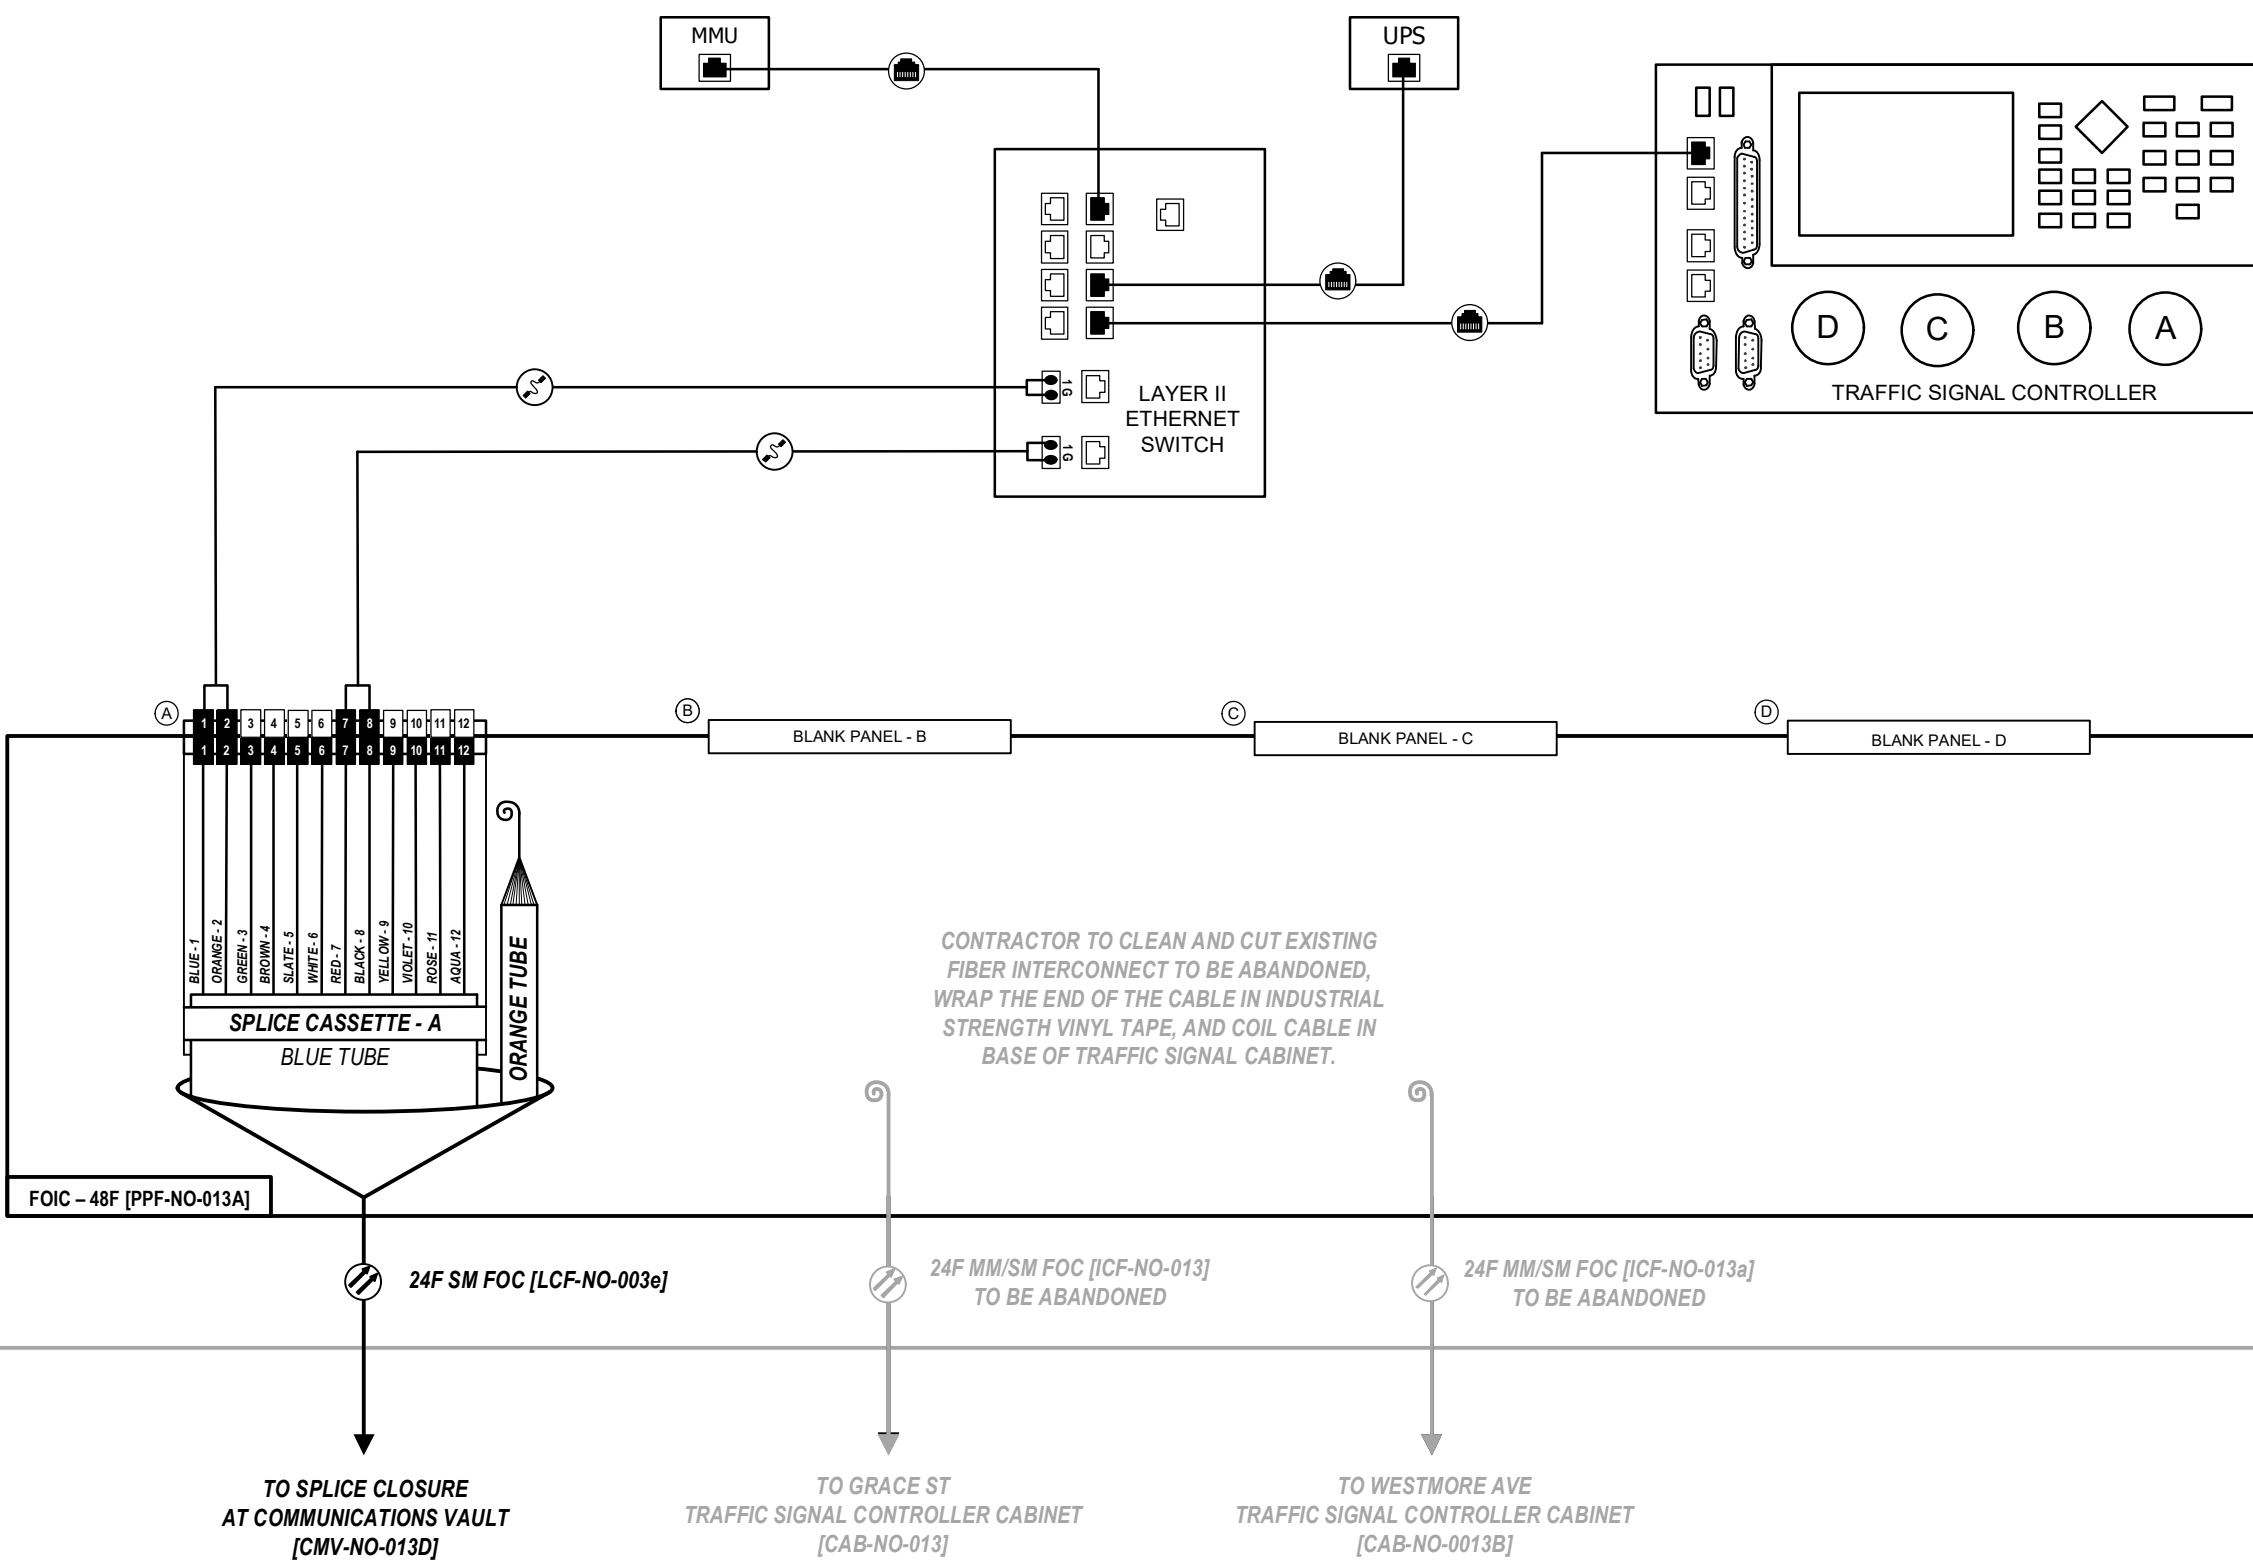

NOTE:
1) ALL FIBER OPTIC JUMP CABLES SHALL BE LC-LC CONNECTOR TYPE UNLESS APPROVED BY THE ENGINEER. NO ADAPTERS OR CONVERSION DEVICES WILL BE ALLOWED.

CONTRACTOR TO CLEAN AND CUT EXISTING FIBER INTERCONNECT TO BE ABANDONED, WRAP THE END OF THE CABLE IN INDUSTRIAL STRENGTH VINYL TAPE, AND COIL CABLE IN BASE OF TRAFFIC SIGNAL CABINET.

TO SPLICE CLOSURE
AT COMMUNICATIONS VAULT
[CMV-NO-013D]

TO GRACE ST
TRAFFIC SIGNAL CONTROLLER CABINET
[CAB-NO-013]

TO WESTMORE AVE
TRAFFIC SIGNAL CONTROLLER CABINET
[CAB-NO-0013B]

D:\08121-sht-comm-visio




USER NAME =	DESIGNED -	REVISED -
	DRAWN -	REVISED -
PLOT SCALE = N.T.S.	CHECKED -	REVISED -
PLOT DATE =	DATE -	REVISED -

STATE OF ILLINOIS
DEPARTMENT OF TRANSPORTATION

FIBER SPLICING AND CABINET CONNECTION DETAILS TRAFFIC SIGNAL CONTROLLER CABINET [CAB-NO-013A]			
SCALE:	SHEET	OF	SHEETS
	STA.		TO STA.

F.A.P. RTE.	SECTION	COUNTY	TOTAL SHEETS	SHEET NO.
307	2020-263-SUR,SW&TS	DUPAGE	529	424
CONTRACT NO. 62N33				
ILLINOIS				

IL 64 (NORTH AVENUE)
AT WESTMORE AVE

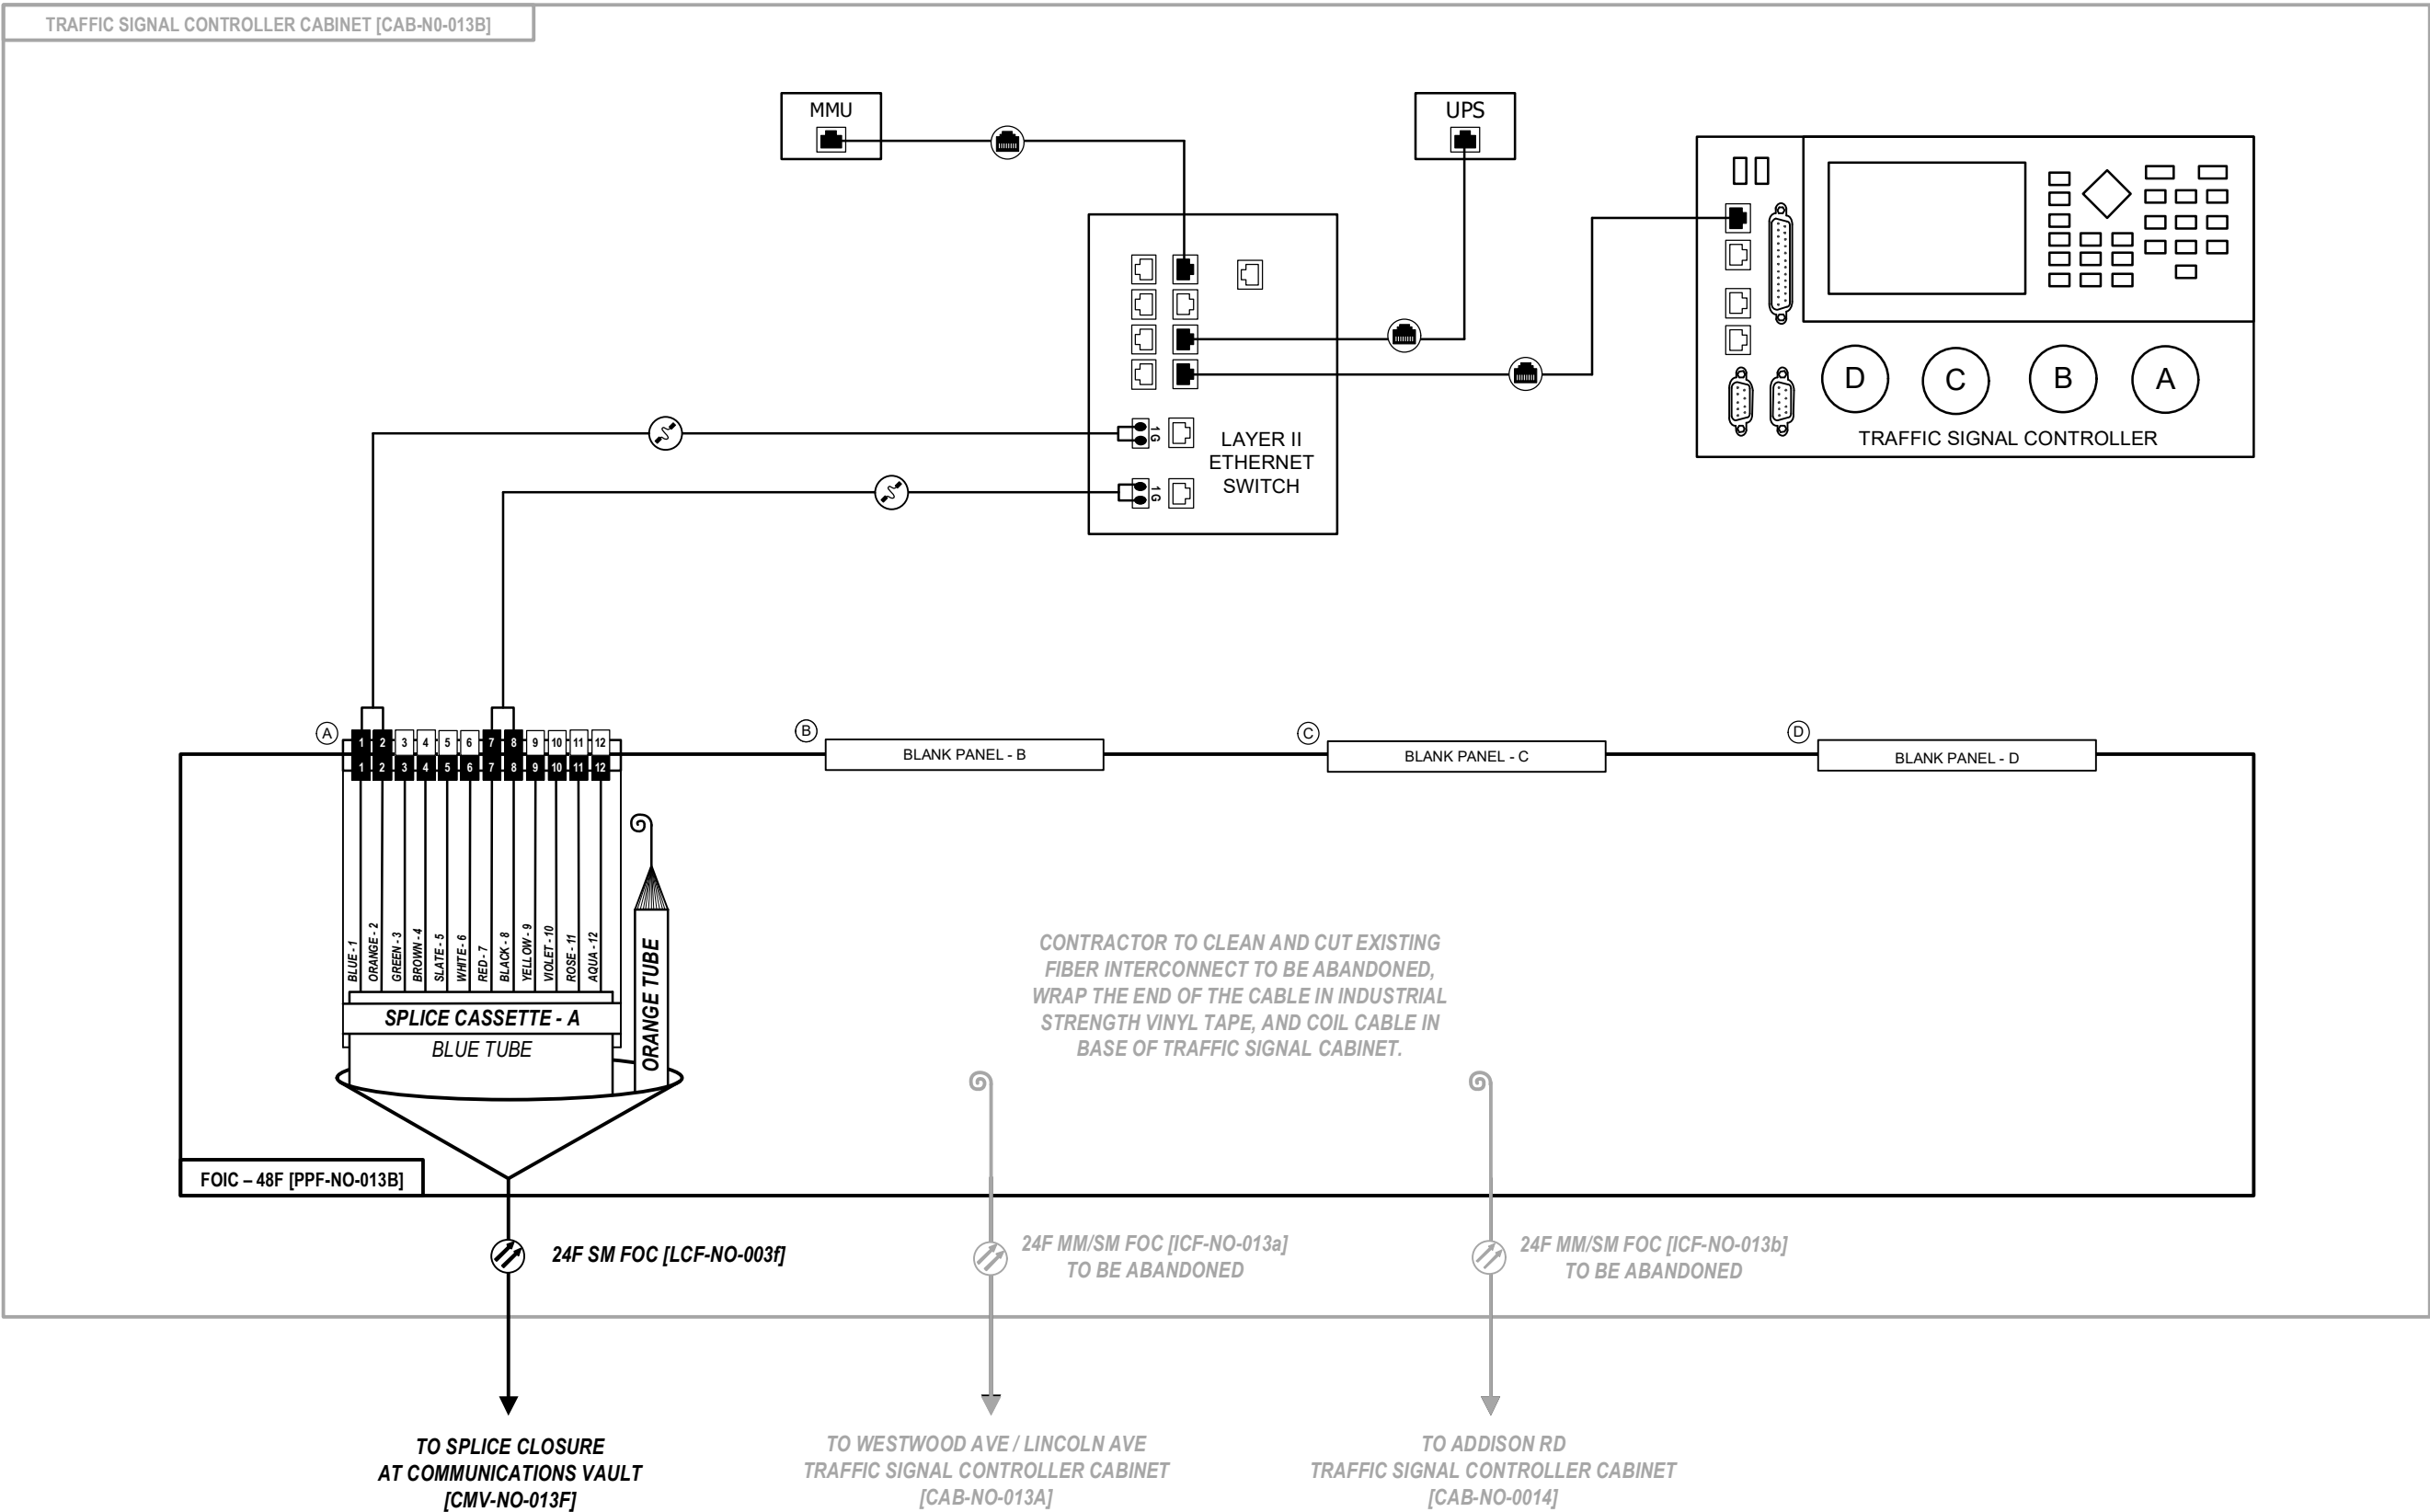

NOTE:
1) ALL FIBER OPTIC JUMP CABLES SHALL BE LC-LC CONNECTOR
TYPE UNLESS APPROVED BY THE ENGINEER. NO ADAPTERS OR
CONVERSION DEVICES WILL BE ALLOWED.

D:\08121-sht-comm-viso

Kimley»Horn

USER NAME =	DESIGNED -	REVISED -
	DRAWN -	REVISED -
PLOT SCALE = N.T.S.	CHECKED -	REVISED -
PLOT DATE =	DATE -	REVISED -


STATE OF ILLINOIS
DEPARTMENT OF TRANSPORTATION

FIBER SPLICING AND CABINET CONNECTION DETAILS
TRAFFIC SIGNAL CONTROLLER CABINET [CAB-NO-013B]

SCALE:	SHEET	OF	SHEETS	STA.	TO STA.
--------	-------	----	--------	------	---------

F.A.P. RTE.	SECTION	COUNTY	TOTAL SHEETS	SHEET NO.
307	2020-263-SUR,SW&TS	DUPAGE	529	425
CONTRACT NO. 62N33				
ILLINOIS				

IL 64 (NORTH AVENUE)
AT MICHIGAN AVE

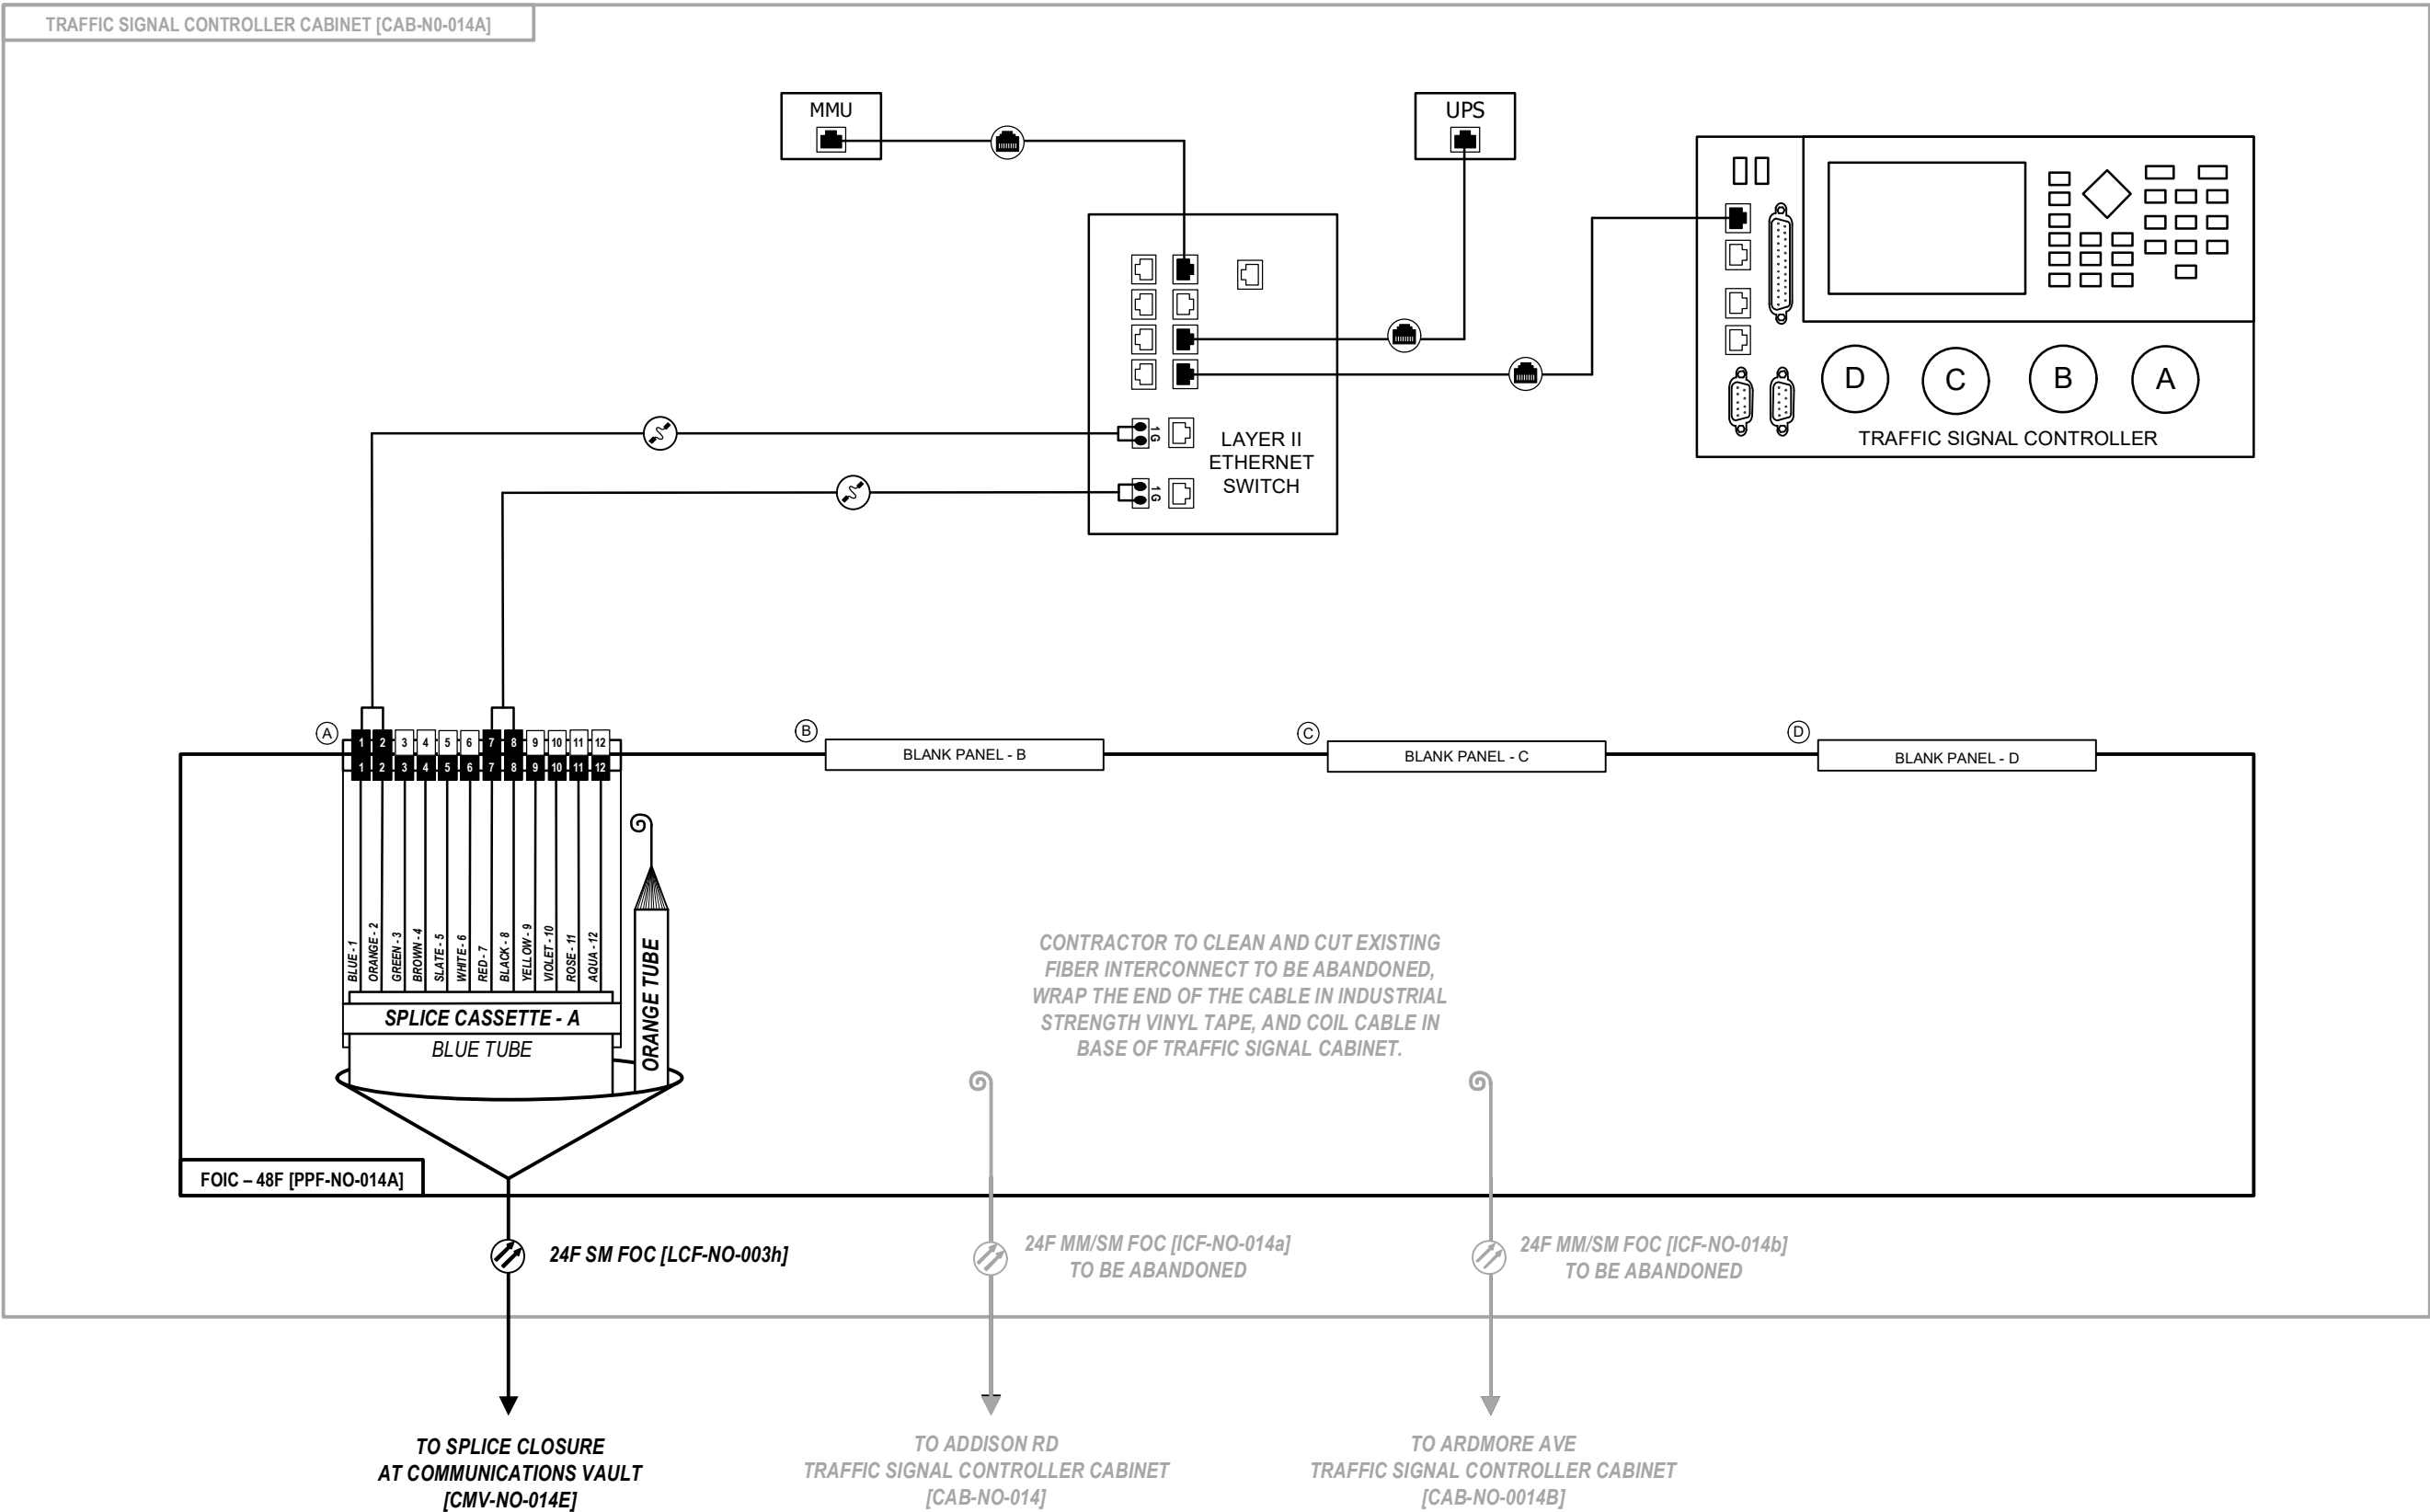

NOTE:
1) ALL FIBER OPTIC JUMP CABLES SHALL BE LC-LC CONNECTOR
TYPE UNLESS APPROVED BY THE ENGINEER. NO ADAPTERS OR
CONVERSION DEVICES WILL BE ALLOWED.

D:\08121-sht-comm-visio

Kimley»Horn

USER NAME =	DESIGNED -	REVISED -
	DRAWN -	REVISED -
PLOT SCALE = N.T.S.	CHECKED -	REVISED -
PLOT DATE =	DATE -	REVISED -


STATE OF ILLINOIS
DEPARTMENT OF TRANSPORTATION

FIBER SPLICING AND CABINET CONNECTION DETAILS
TRAFFIC SIGNAL CONTROLLER CABINET [CAB-NO-014A]

SCALE:	SHEET	OF	SHEETS	STA.	TO STA.
--------	-------	----	--------	------	---------

F.A.P. RTE.	SECTION	COUNTY	TOTAL SHEETS	SHEET NO.
307	2020-263-SUR,SW&TS	DUPAGE	529	427
CONTRACT NO. 62N33				
ILLINOIS				

IL 64 (NORTH AVENUE)
AT ARDMORE AVE

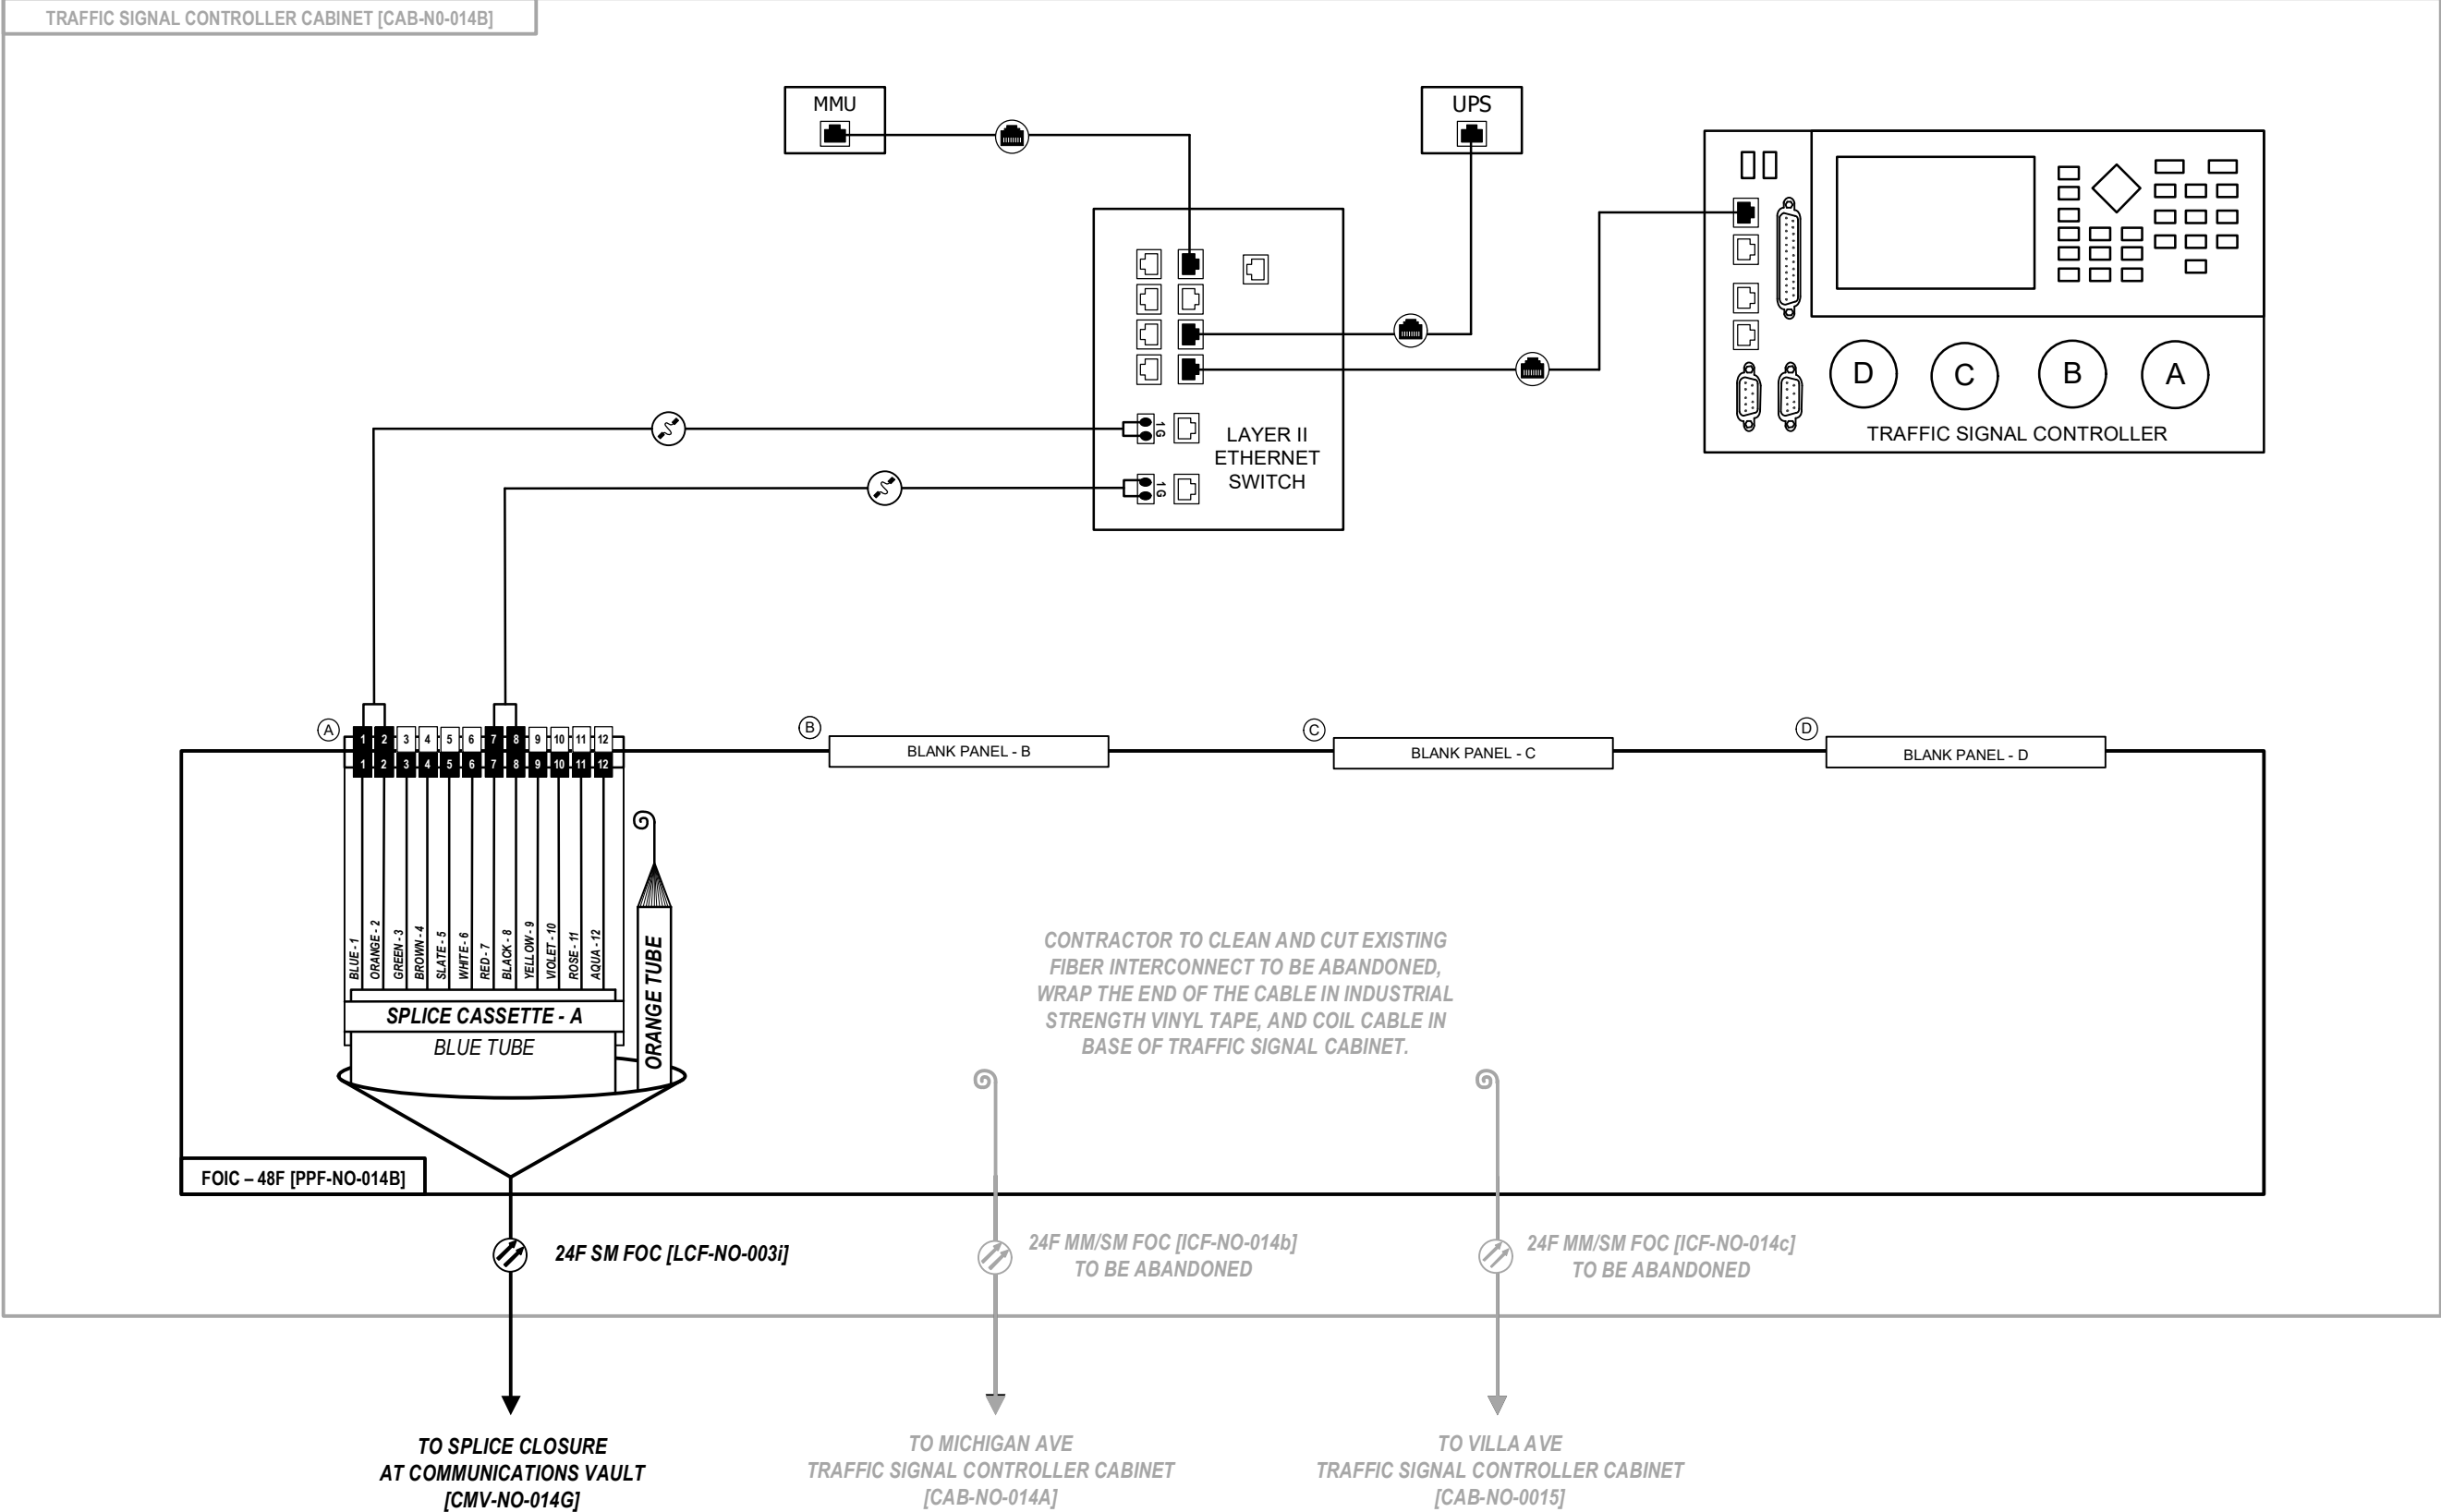

NOTE:
1) ALL FIBER OPTIC JUMP CABLES SHALL BE LC-LC CONNECTOR
TYPE UNLESS APPROVED BY THE ENGINEER. NO ADAPTERS OR
CONVERSION DEVICES WILL BE ALLOWED.

D:\08121-sht-comm-visio

Kimley»Horn

USER NAME =	DESIGNED -	REVISED -
	DRAWN -	REVISED -
PLOT SCALE = N.T.S.	CHECKED -	REVISED -
PLOT DATE =	DATE -	REVISED -

STATE OF ILLINOIS
DEPARTMENT OF TRANSPORTATION


FIBER SPLICING AND CABINET CONNECTION DETAILS
TRAFFIC SIGNAL CONTROLLER CABINET [CAB-NO-014B]

SCALE:	SHEET	OF	SHEETS	STA.	TO STA.
--------	-------	----	--------	------	---------

F.A.P. RTE.	SECTION	COUNTY	TOTAL SHEETS	SHEET NO.
307	2020-263-SUR,SW&TS	DUPAGE	529	428
CONTRACT NO. 62N33				
ILLINOIS				

IL 64 (NORTH AVENUE)
AT VILLA AVE

TRAFFIC SIGNAL CONTROLLER CABINET [CAB-NO-015]

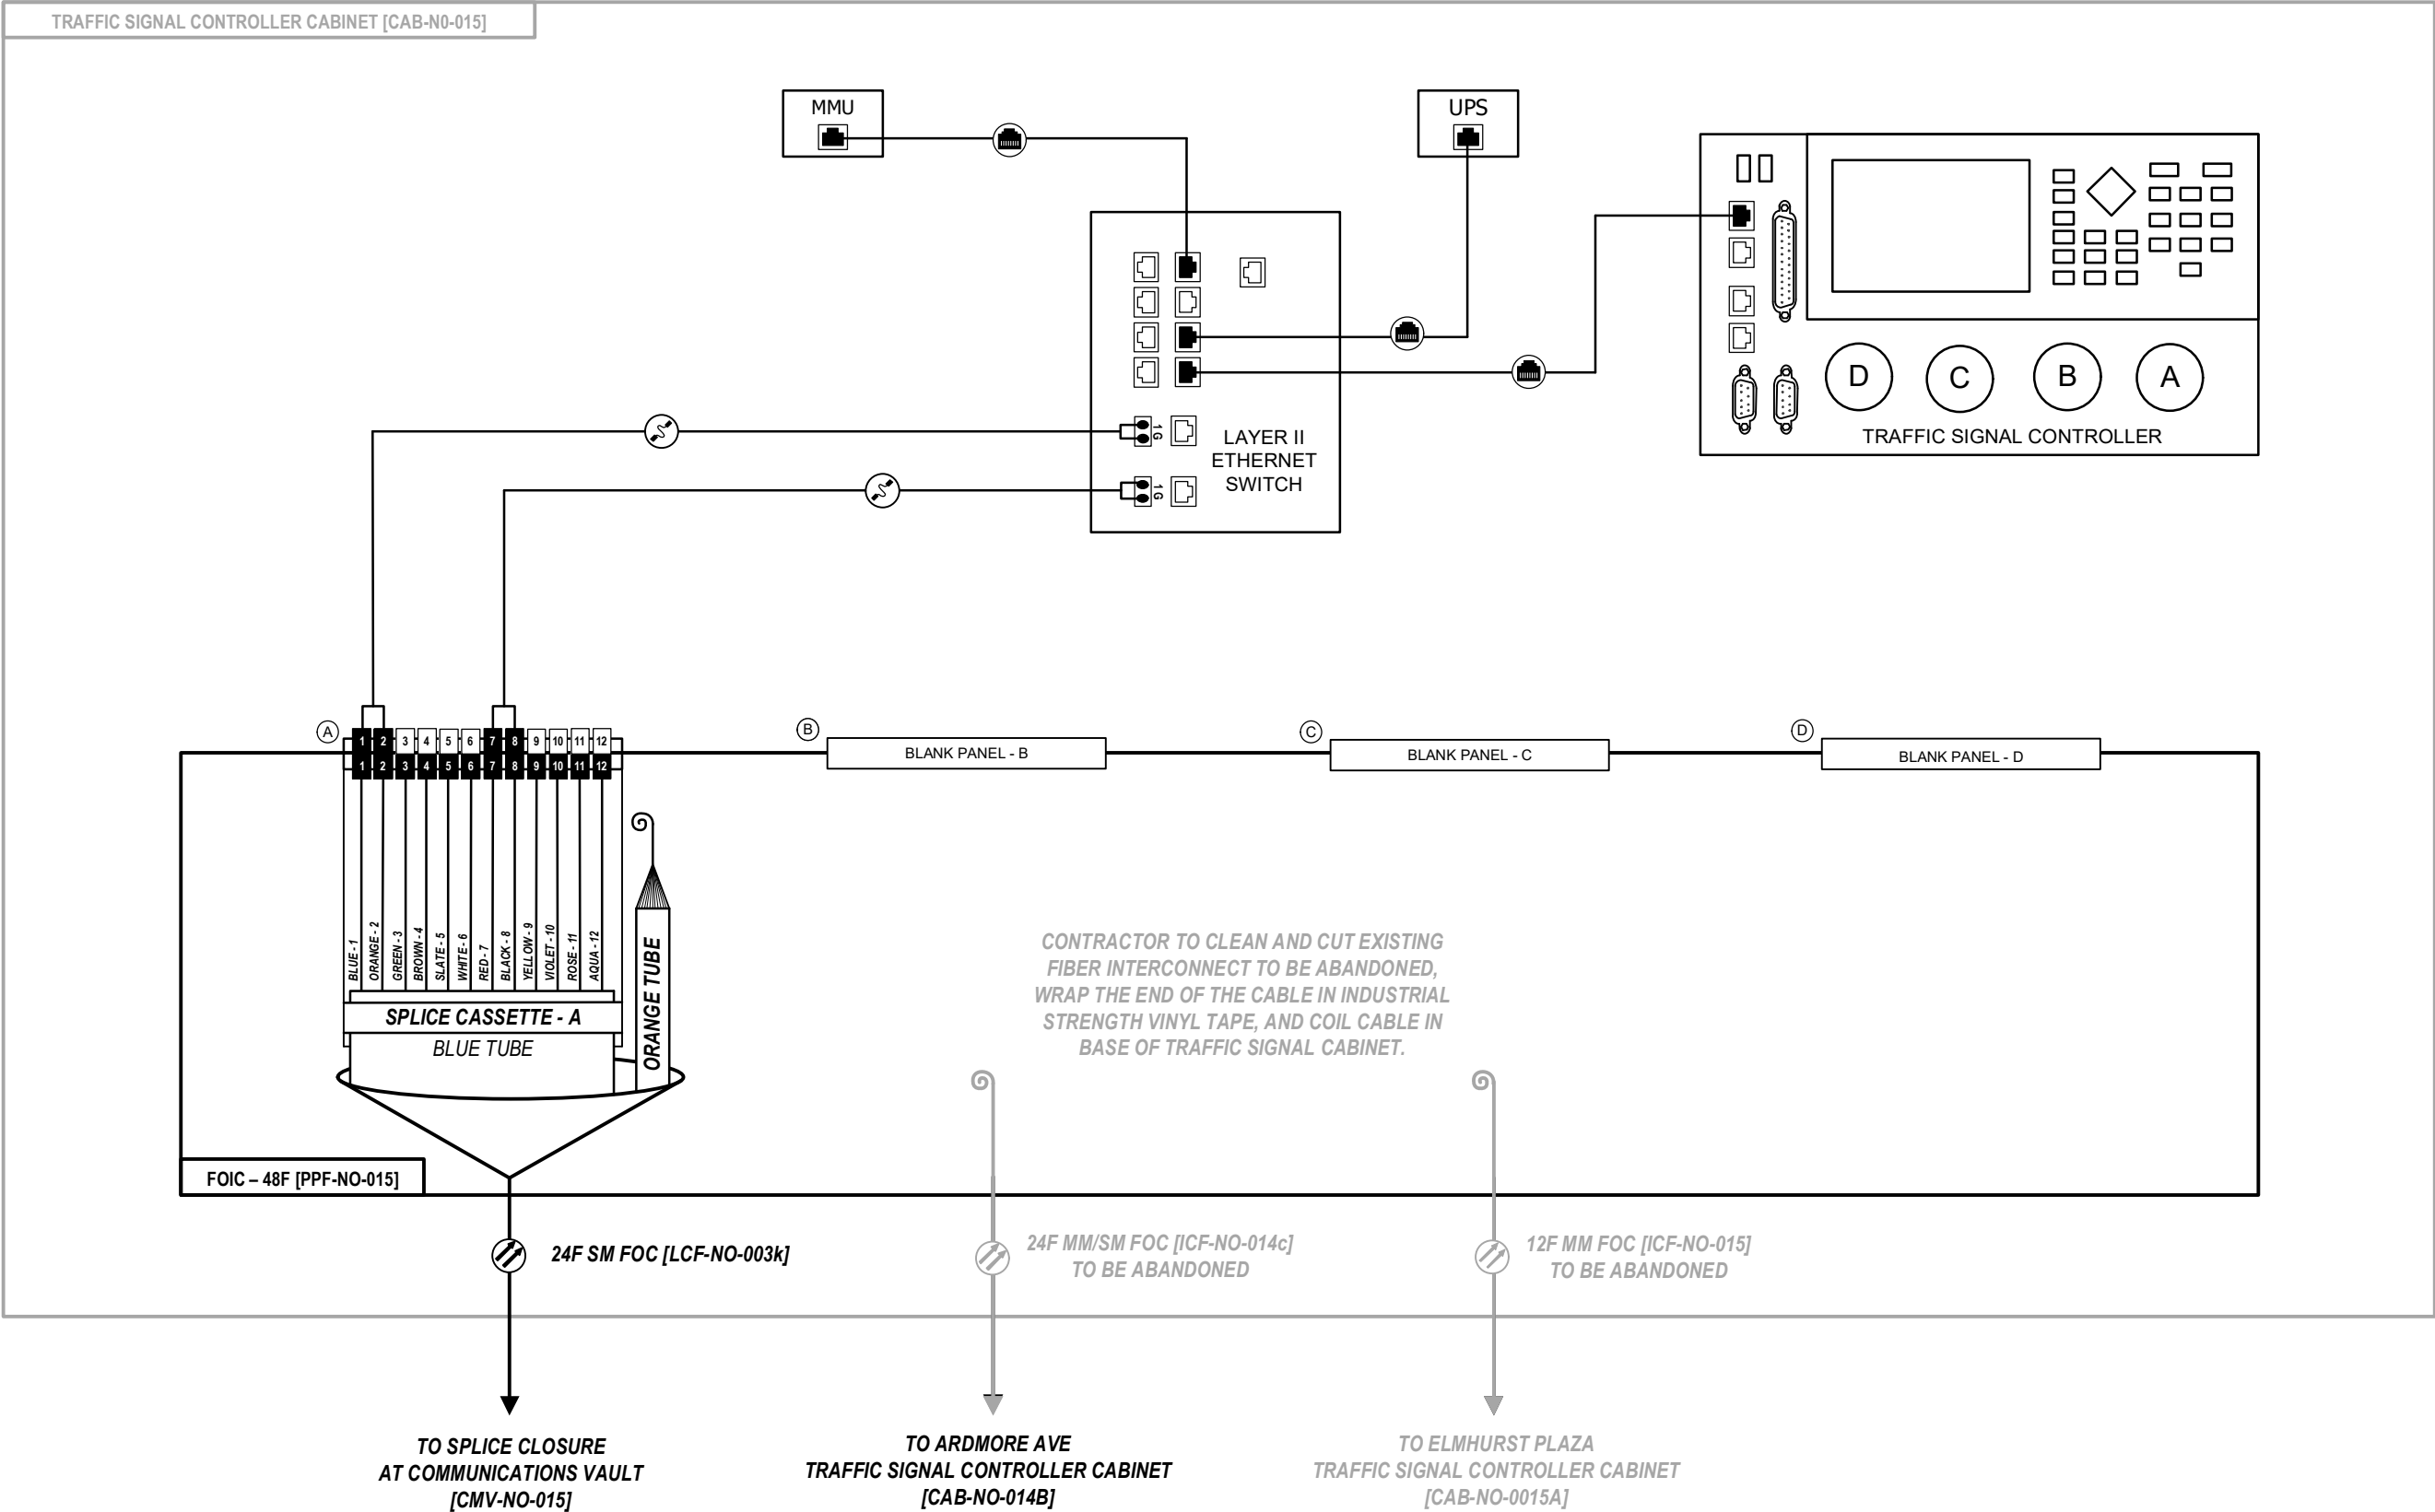

D:\08121-sht-comm-visio

Kimley»Horn

USER NAME =	DESIGNED -	REVISED -
	DRAWN -	REVISED -
PLOT SCALE = N.T.S.	CHECKED -	REVISED -
PLOT DATE =	DATE -	REVISED -


STATE OF ILLINOIS
DEPARTMENT OF TRANSPORTATION

FIBER SPLICING AND CABINET CONNECTION DETAILS
TRAFFIC SIGNAL CONTROLLER CABINET [CAB-NO-015]

SCALE:	SHEET	OF	SHEETS	STA.	TO STA.
--------	-------	----	--------	------	---------

F.A.P. RTE.	SECTION	COUNTY	TOTAL SHEETS	SHEET NO.
307	2020-263-SUR,SW&TS	DUPAGE	529	430
CONTRACT NO. 62N33				
ILLINOIS				

IL 64 (NORTH AVENUE)
AT ELMHURST PLAZA

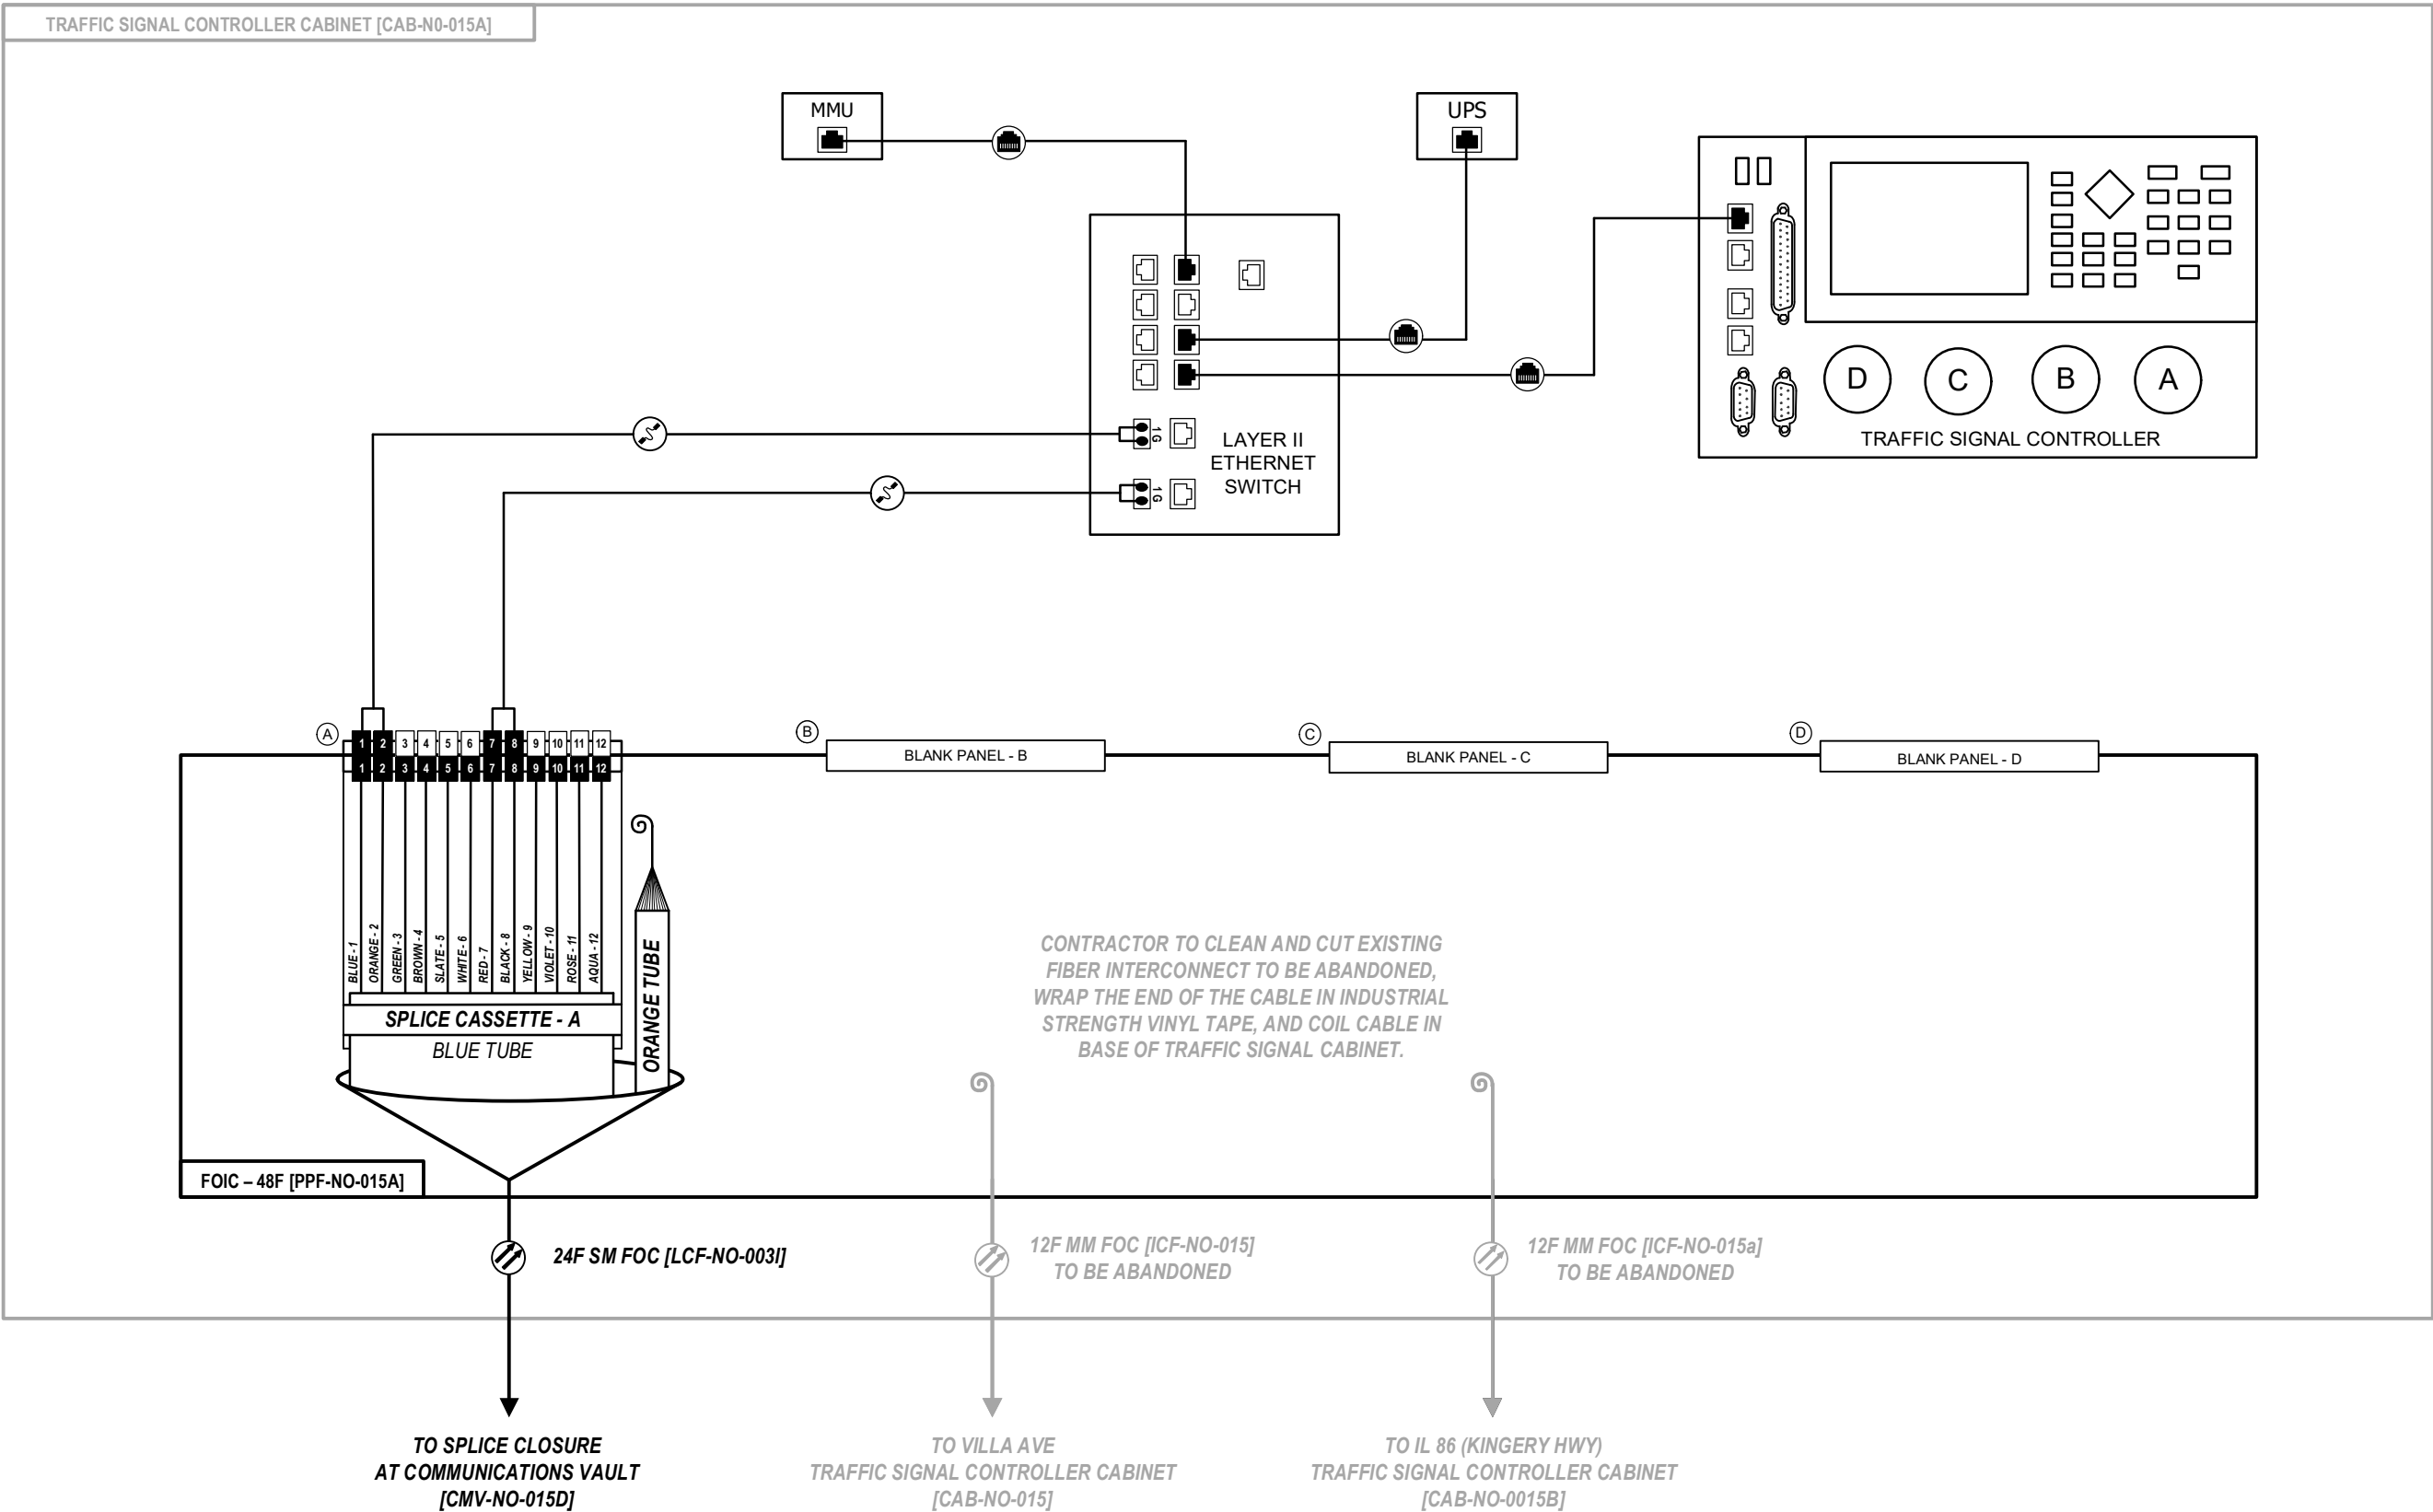

D:\08121-sht-comm-visio

Kimley»Horn


USER NAME =	DESIGNED -	REVISED -
	DRAWN -	REVISED -
PLOT SCALE = N.T.S.	CHECKED -	REVISED -
PLOT DATE =	DATE -	REVISED -

STATE OF ILLINOIS
DEPARTMENT OF TRANSPORTATION

FIBER SPLICING AND CABINET CONNECTION DETAILS
TRAFFIC SIGNAL CONTROLLER CABINET [CAB-NO-015A]

SCALE: SHEET OF SHEETS STA. TO STA.

F.A.P. RTE.	SECTION	COUNTY	TOTAL SHEETS	SHEET NO.
307	2020-263-SUR,SW&TS	DUPAGE	529	431
CONTRACT NO. 62N33				
ILLINOIS FED. AID PROJECT				

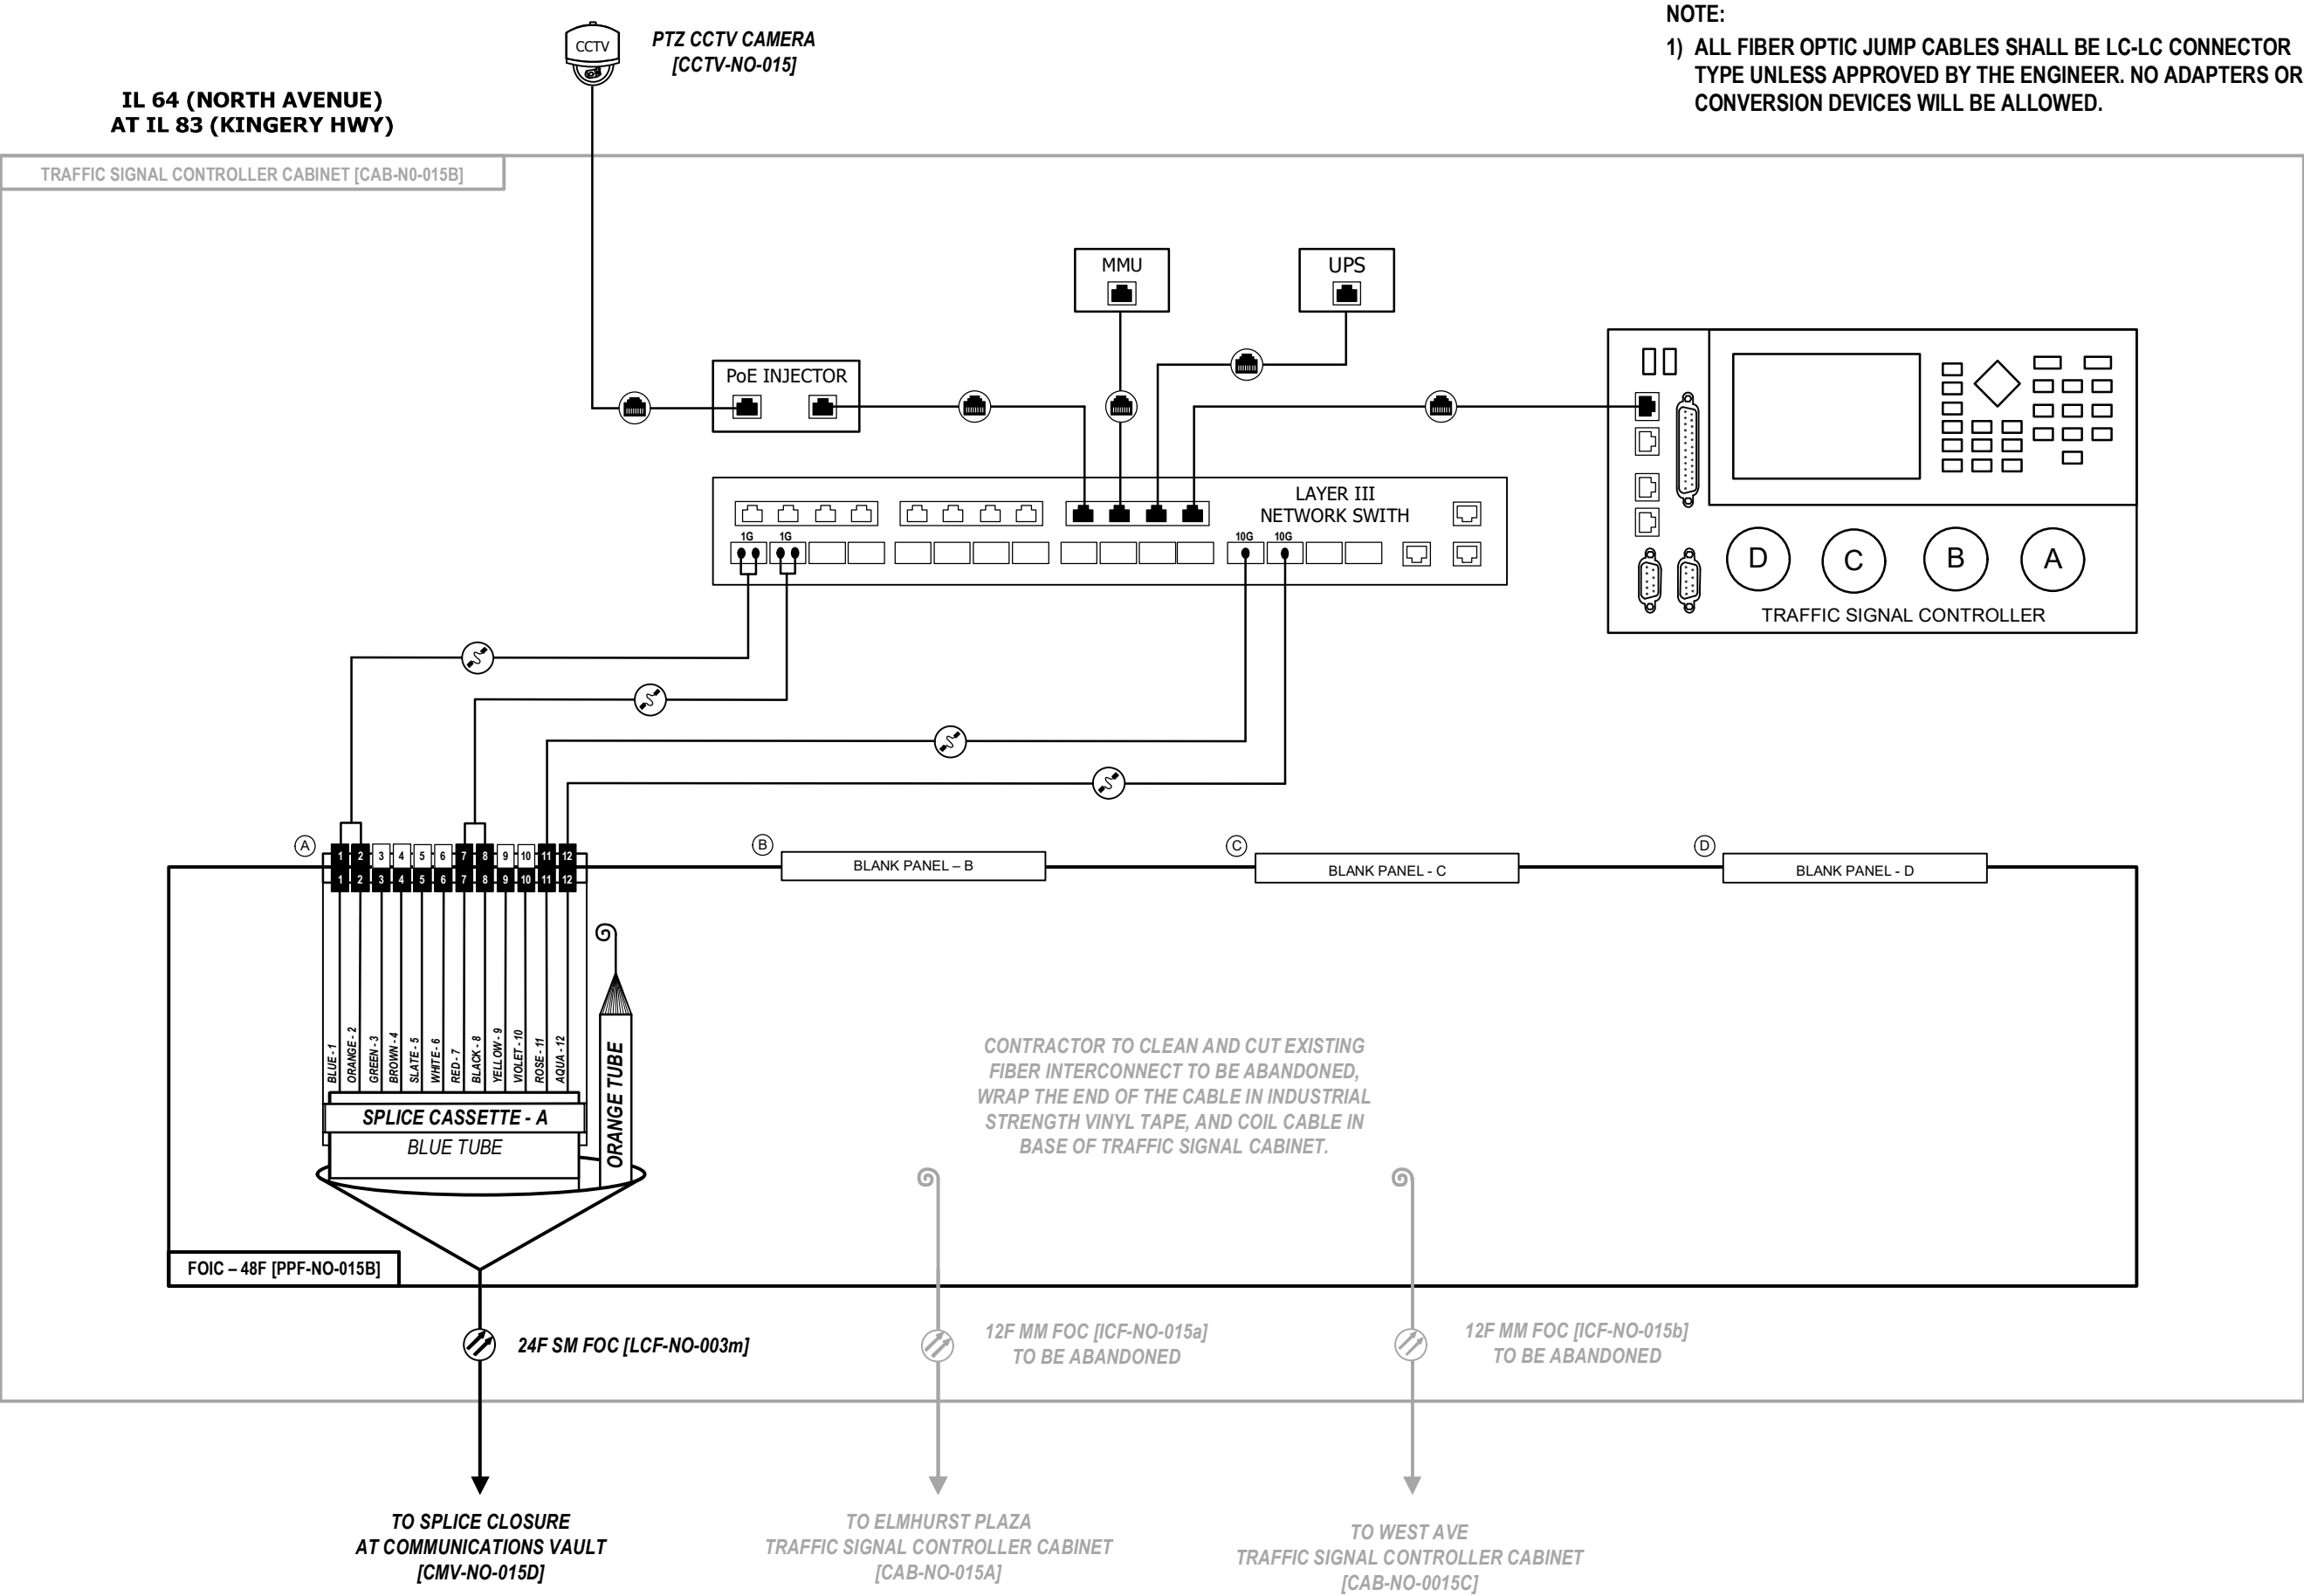

D:\08121-sht-comm-viso

Kimley»Horn

USER NAME =	DESIGNED -	REVISED -
	DRAWN -	REVISED -
PLOT SCALE = N.T.S.	CHECKED -	REVISED -
PLOT DATE =	DATE -	REVISED -


STATE OF ILLINOIS
DEPARTMENT OF TRANSPORTATION

FIBER SPLICING AND CABINET CONNECTION DETAILS
TRAFFIC SIGNAL CONTROLLER CABINET [CAB-NO-015B]

SCALE:	SHEET	OF	SHEETS	STA.	TO STA.
--------	-------	----	--------	------	---------

F.A.P. RTE.	SECTION	COUNTY	TOTAL SHEETS	SHEET NO.
307	2020-263-SUR,SW&TS	DUPAGE	529	432
CONTRACT NO. 62N33				
ILLINOIS FED. AID PROJECT				

IL 64 (NORTH AVENUE)
AT WEST AVE

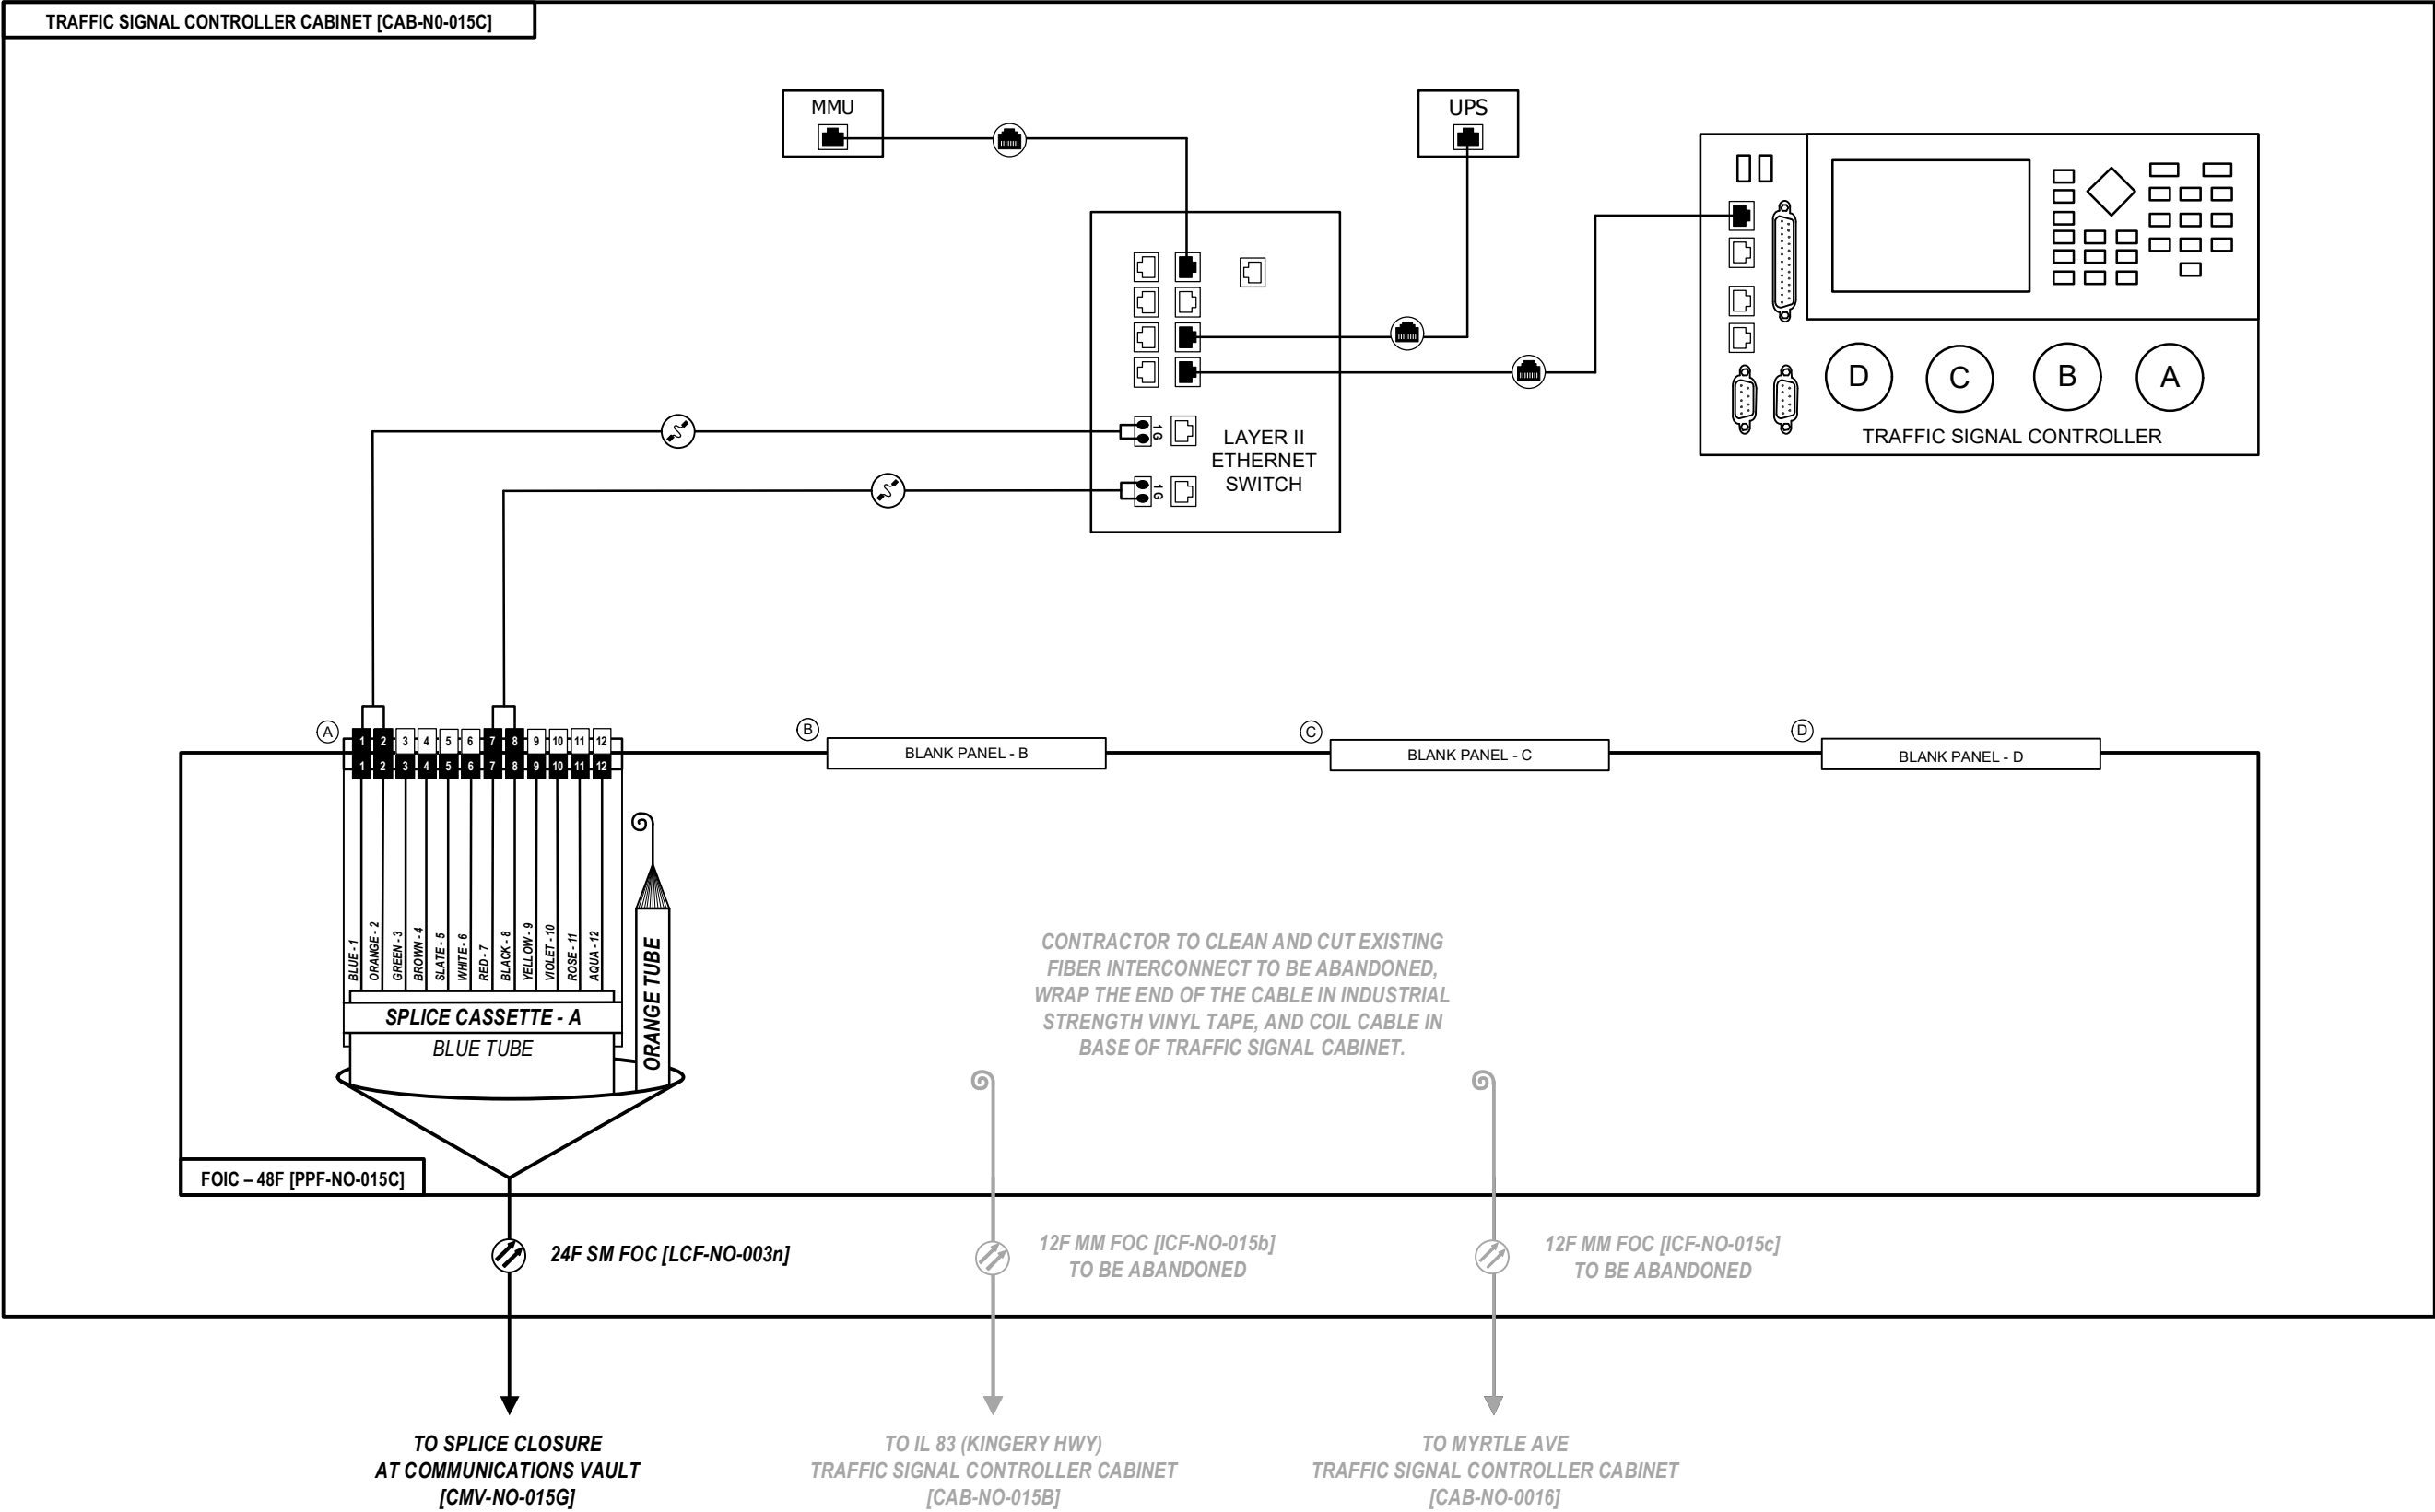

NOTE:
1) ALL FIBER OPTIC JUMP CABLES SHALL BE LC-LC CONNECTOR
TYPE UNLESS APPROVED BY THE ENGINEER. NO ADAPTERS OR
CONVERSION DEVICES WILL BE ALLOWED.

D:\08121-sht-comm-visio

Kimley»Horn

USER NAME =	DESIGNED -	REVISED -
	DRAWN -	REVISED -
PLOT SCALE = N.T.S.	CHECKED -	REVISED -
PLOT DATE =	DATE -	REVISED -

STATE OF ILLINOIS
DEPARTMENT OF TRANSPORTATION


FIBER SPLICING AND CABINET CONNECTION DETAILS
TRAFFIC SIGNAL CONTROLLER CABINET [CAB-NO-015C]

SCALE:	SHEET	OF	SHEETS	STA.	TO STA.
--------	-------	----	--------	------	---------

F.A.P. RTE.	SECTION	COUNTY	TOTAL SHEETS	SHEET NO.
307	2020-263-SUR,SW&TS	DUPAGE	529	433
CONTRACT NO. 62N33				
ILLINOIS				

IL 64 (NORTH AVENUE)
AT MYRTLE AVE

TRAFFIC SIGNAL CONTROLLER CABINET [CAB-NO-016]

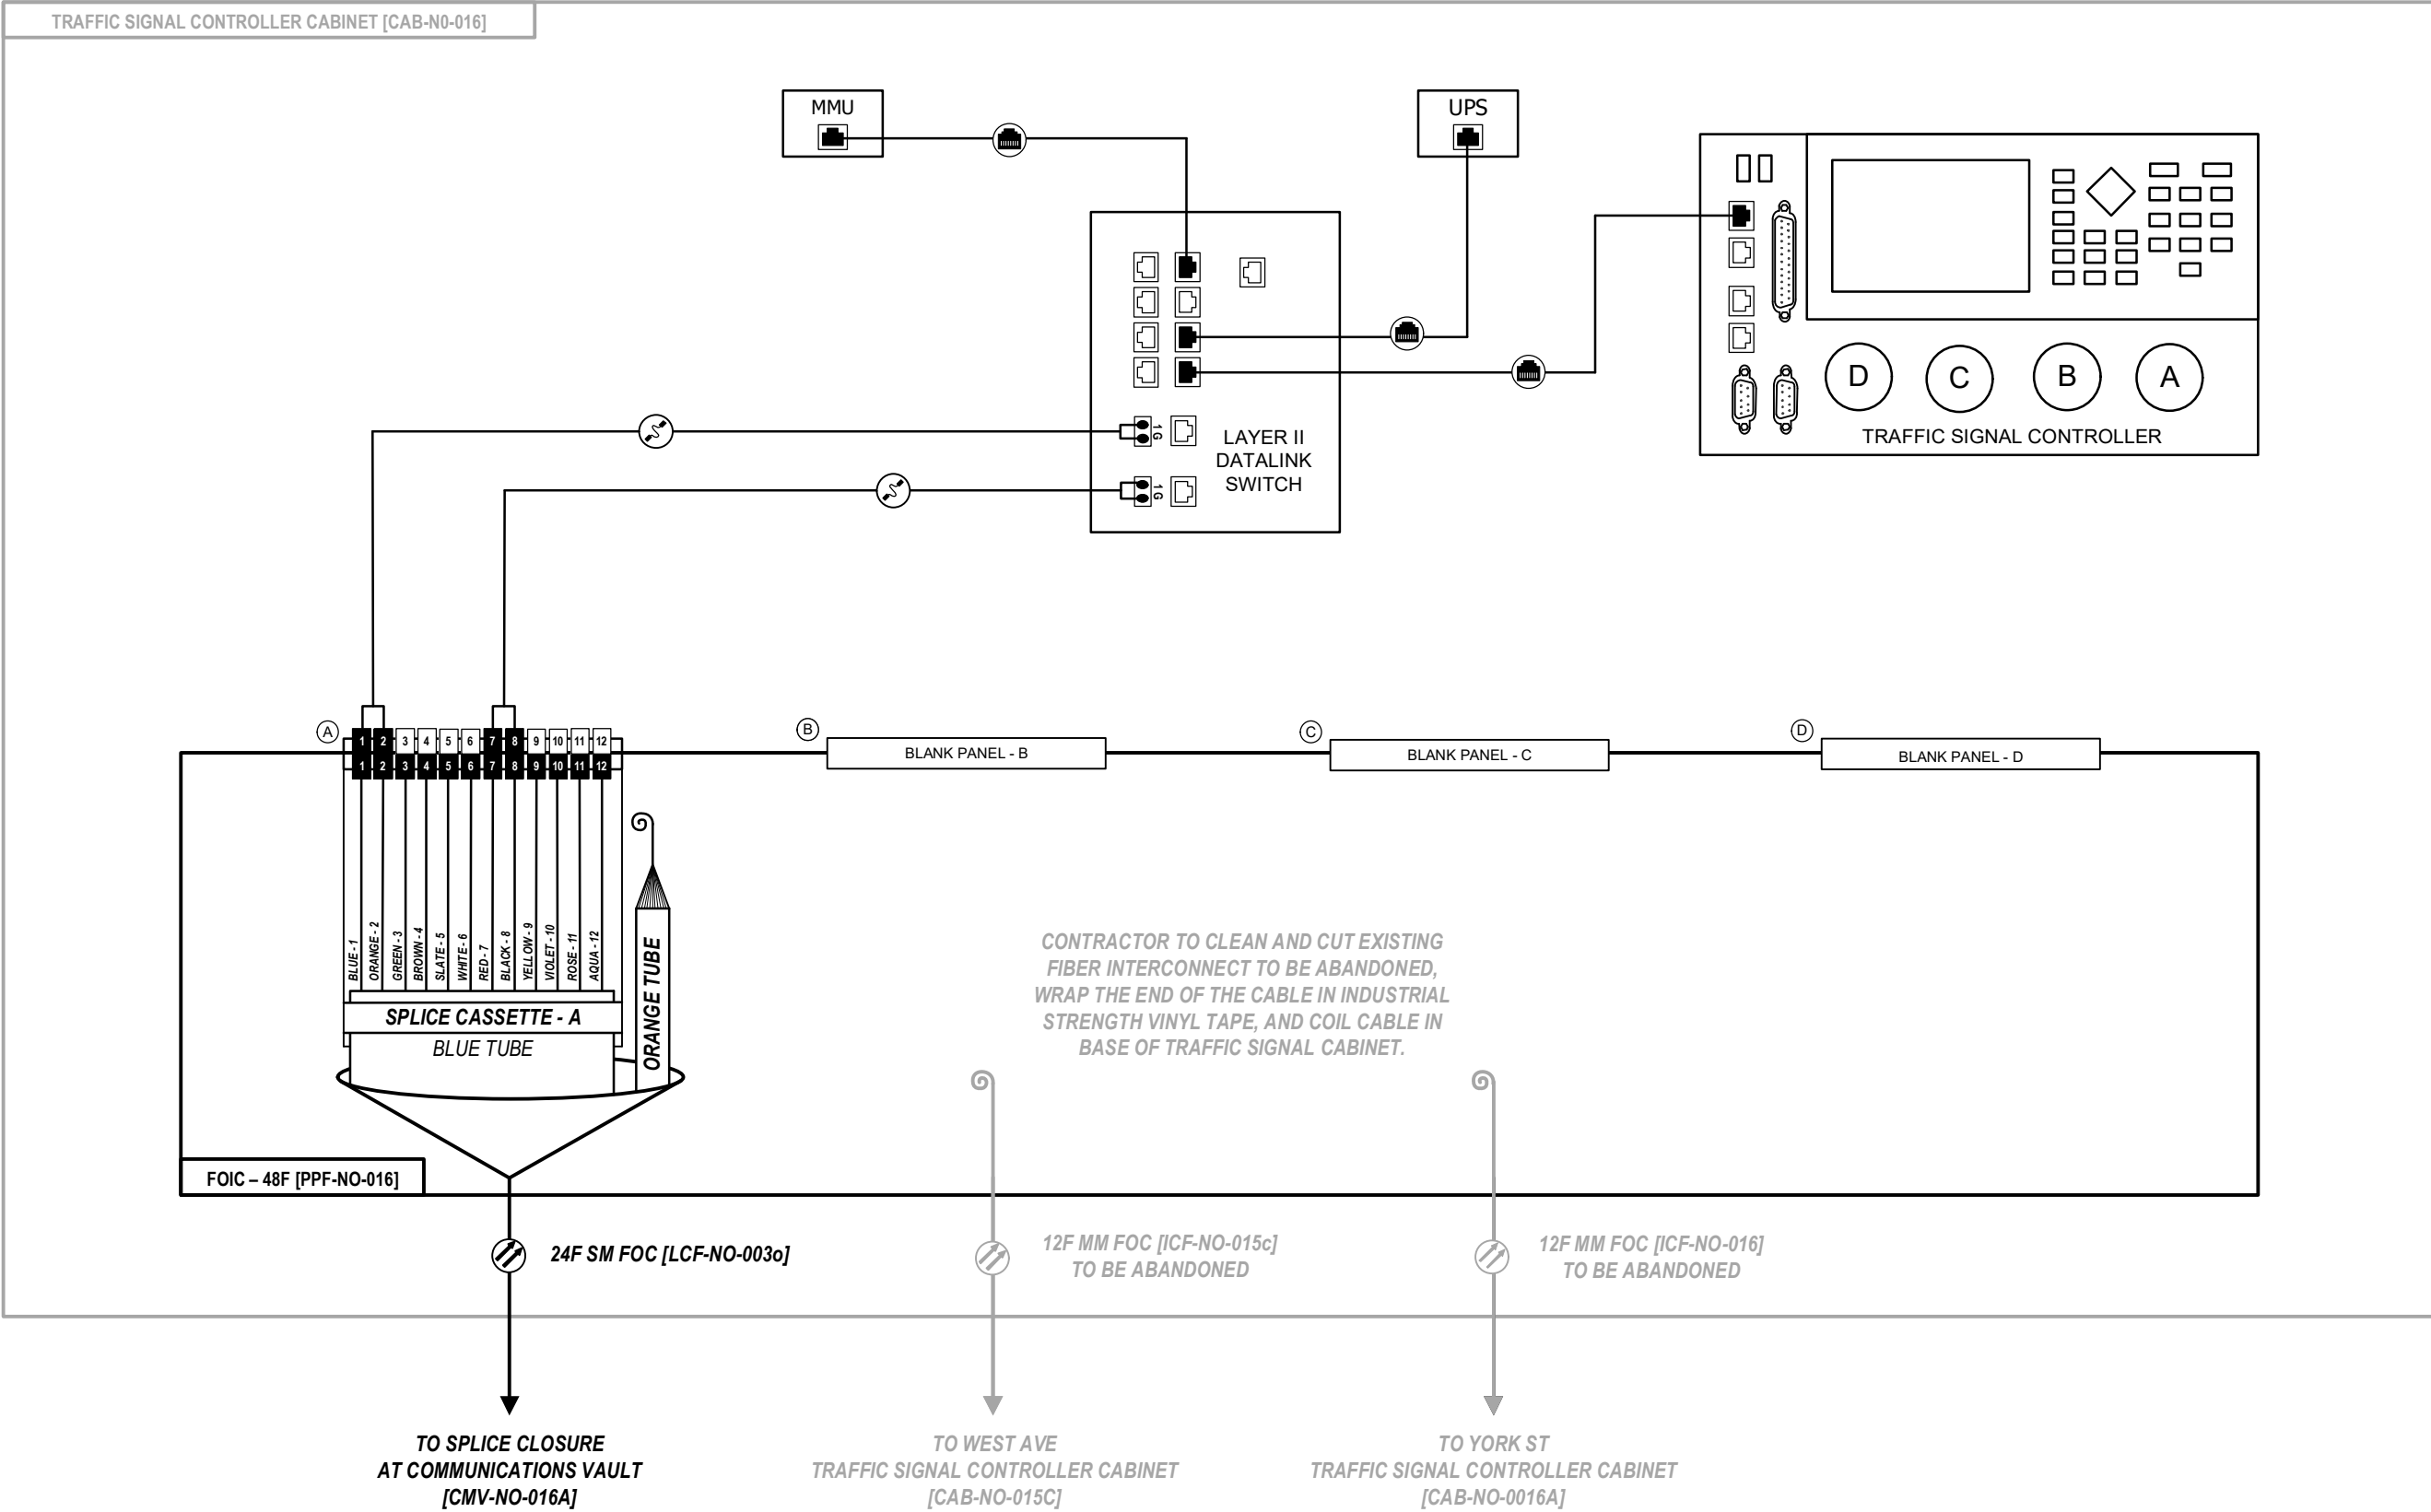

D:\08121-sht-comm-visio

Kimley»Horn


USER NAME =	DESIGNED -	REVISED -
	DRAWN -	REVISED -
PLOT SCALE = N.T.S.	CHECKED -	REVISED -
PLOT DATE =	DATE -	REVISED -

STATE OF ILLINOIS
DEPARTMENT OF TRANSPORTATION

FIBER SPLICING AND CABINET CONNECTION DETAILS
TRAFFIC SIGNAL CONTROLLER CABINET [CAB-NO-016]

SCALE: SHEET OF SHEETS STA. TO STA.

F.A.P. RTE.	SECTION	COUNTY	TOTAL SHEETS	SHEET NO.
307	2020-263-SUR,SW&TS	DUPAGE	529	434
CONTRACT NO. 62N33				
ILLINOIS FED. AID PROJECT				

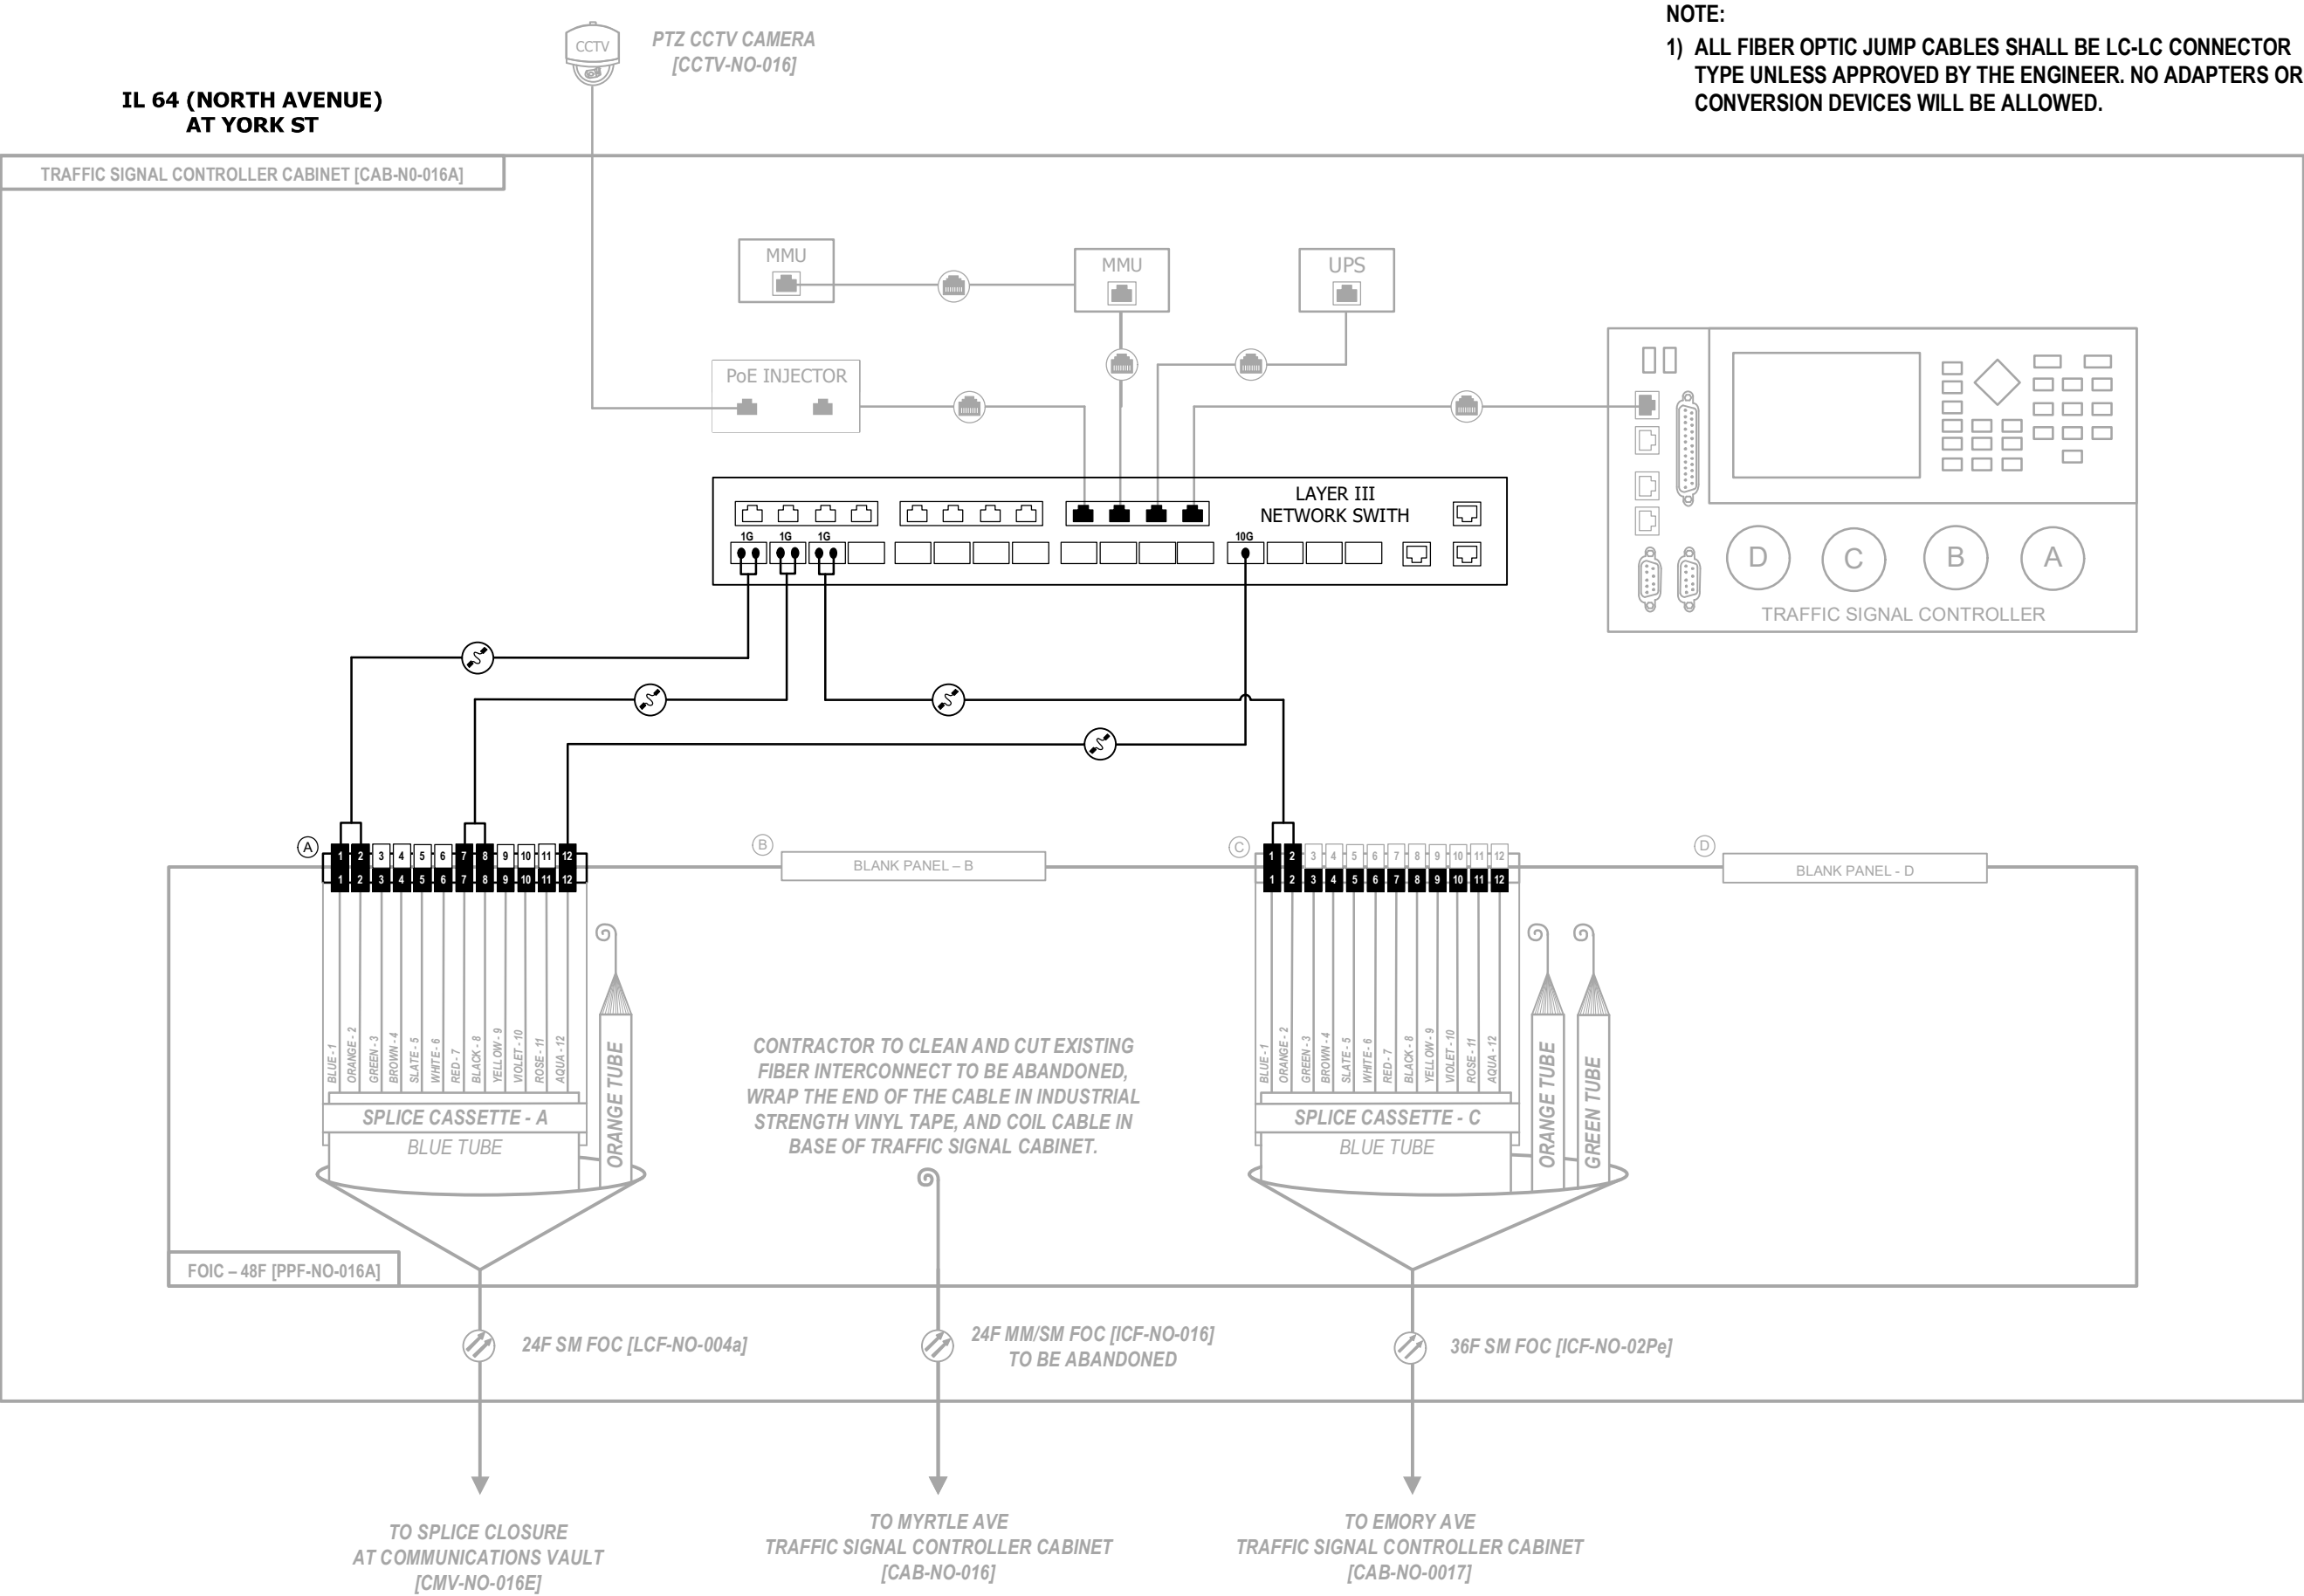

D:\08121-sht-comm-viso

Kimley»Horn

USER NAME =	DESIGNED -	REVISED -
	DRAWN -	REVISED -
PLOT SCALE = N.T.S.	CHECKED -	REVISED -
PLOT DATE =	DATE -	REVISED -

STATE OF ILLINOIS
DEPARTMENT OF TRANSPORTATION

FIBER SPLICING AND CABINET CONNECTION DETAILS
TRAFFIC SIGNAL CONTROLLER CABINET [CAB-NO-016A]

SCALE:	SHEET	OF	SHEETS	STA.	TO STA.
--------	-------	----	--------	------	---------

F.A.P. RTE.	SECTION	COUNTY	TOTAL SHEETS	SHEET NO.
307	2020-263-SUR,SW&TS	DUPAGE	529	435
CONTRACT NO. 62N33				
ILLINOIS				

TRUNK CABLE FIBER ASSIGNMENTS				ORIGINATION	CAB-NO-002C (IDOT COMMUNICATIONS NODE)		
CABLE DESIGNATION		TCF-NO-002		DESTINATION	CAB-NO-011C (IDOT COMMUNICATIONS NODE)		
BUFFER TUBE	FIBER	FIBER NO.	ASSIGNMENT	BUFFER TUBE	FIBER	FIBER NO.	ASSIGNMENT
BLUE	Blue 1	1	IL 59 NODE CABINET TO I-355 NODE CABINET (10G LINK)	RED	Blue 1	73	DARK
	Orange 2	2	DARK		Orange 2	74	DARK
	Green 3	3	IL 59 NODE CABINET TO NORDIC TOWER CORE SWITCH (10G LINK)		Green 3	75	DARK
	Brown 4	4	DARK		Brown 4	76	DARK
	Slate 5	5	IL 59 NODE CABINET TO HILLSIDE TOWER CORE SWITCH (10G LINK)		Slate 5	77	DARK
	White 6	6	DARK		White 6	78	DARK
	Red 7	7	DARK		Red 7	79	DARK
	Black 8	8	DARK		Black 8	80	DARK
	Yellow 9	9	DARK		Yellow 9	81	DARK
	Violet 10	10	DARK		Violet 10	82	DARK
	Rose 11	11	DARK		Rose 11	83	DARK
	Aqua 12	12	DARK		Aqua 12	84	DARK
ORANGE	Blue 1	13	DARK	BLACK	Blue 1	85	DARK
	Orange 2	14	DARK		Orange 2	86	DARK
	Green 3	15	DARK		Green 3	87	DARK
	Brown 4	16	DARK		Brown 4	88	DARK
	Slate 5	17	DARK		Slate 5	89	DARK
	White 6	18	DARK		White 6	90	DARK
	Red 7	19	DARK		Red 7	91	DARK
	Black 8	20	DARK		Black 8	92	DARK
	Yellow 9	21	DARK		Yellow 9	93	DARK
	Violet 10	22	DARK		Violet 10	94	DARK
	Rose 11	23	DARK		Rose 11	95	DARK
	Aqua 12	24	DARK		Aqua 12	96	DARK
GREEN	Blue 1	25	DARK	YELLOW	Blue 1	97	DARK
	Orange 2	26	DARK		Orange 2	98	DARK
	Green 3	27	DARK		Green 3	99	DARK
	Brown 4	28	DARK		Brown 4	100	DARK
	Slate 5	29	DARK		Slate 5	101	DARK
	White 6	30	DARK		White 6	102	DARK
	Red 7	31	DARK		Red 7	103	DARK
	Black 8	32	DARK		Black 8	104	DARK
	Yellow 9	33	DARK		Yellow 9	105	DARK
	Violet 10	34	DARK		Violet 10	106	DARK
	Rose 11	35	DARK		Rose 11	107	DARK
	Aqua 12	36	DARK		Aqua 12	108	DARK
BROWN	Blue 1	37	DARK	VIOLET	Blue 1	109	DARK
	Orange 2	38	DARK		Orange 2	110	DARK
	Green 3	39	DARK		Green 3	111	DARK
	Brown 4	40	DARK		Brown 4	112	DARK
	Slate 5	41	DARK		Slate 5	113	DARK
	White 6	42	DARK		White 6	114	DARK
	Red 7	43	DARK		Red 7	115	DARK
	Black 8	44	DARK		Black 8	116	DARK
	Yellow 9	45	DARK		Yellow 9	117	DARK
	Violet 10	46	DARK		Violet 10	118	DARK
	Rose 11	47	DARK		Rose 11	119	DARK
	Aqua 12	48	DARK		Aqua 12	120	DARK
SLATE	Blue 1	49	DARK	ROSE	Blue 1	121	DARK
	Orange 2	50	DARK		Orange 2	122	DARK
	Green 3	51	DARK		Green 3	123	DARK
	Brown 4	52	DARK		Brown 4	124	DARK
	Slate 5	53	DARK		Slate 5	125	DARK
	White 6	54	DARK		White 6	126	DARK
	Red 7	55	DARK		Red 7	127	DARK
	Black 8	56	DARK		Black 8	128	DARK
	Yellow 9	57	DARK		Yellow 9	129	DARK
	Violet 10	58	DARK		Violet 10	130	DARK
	Rose 11	59	DARK		Rose 11	131	DARK
	Aqua 12	60	DARK		Aqua 12	132	DARK
WHITE	Blue 1	61	DARK	AQUA	Blue 1	133	DARK
	Orange 2	62	DARK		Orange 2	134	DARK
	Green 3	63	DARK		Green 3	135	DARK
	Brown 4	64	DARK		Brown 4	136	DARK
	Slate 5	65	DARK		Slate 5	137	DARK
	White 6	66	DARK		White 6	138	DARK
	Red 7	67	DARK		Red 7	139	DARK
	Black 8	68	DARK		Black 8	140	DARK
	Yellow 9	69	DARK		Yellow 9	141	DARK
	Violet 10	70	DARK		Violet 10	142	DARK
	Rose 11	71	DARK		Rose 11	143	DARK
	Aqua 12	72	DARK		Aqua 12	144	DARK

Kimley»Horn © 2022 KIMLEY-HORN AND ASSOCIATES, INC. 400 WEST O ROAD, SUITE 600 WARREN, I.E. 60555 PHONE: 630-447-4500 WWW.KIMLEY-HORN.COM	USER NAME =	DESIGNED -	REVISED -	STATE OF ILLINOIS DEPARTMENT OF TRANSPORTATION	FIBER OPTIC TRUNK CABLE SPLICE ASSIGNMENTS TCF-NO-002				F.A.P. RTE.	SECTION	COUNTY	TOTAL SHEETS	SHEET NO.
	PLOT SCALE =	DRAWN -	REVISED -						307	2020-263-SUR, SW&TS	DUPAGE	529	436
	PLOT DATE =	CHECKED -	REVISED -		CONTRACT NO. 62N33								
		DATE -	REVISED -										
					SCALE:	SHEET	OF	SHEETS	STA.	TO STA.			

MODEL: Default
FILE: \\ntc-01\ntc-pw-bentley.com\ktpw-d1\Documents\01 Active Projects\WW-CUS-16895\100 - IL 64\Phase II\2 Design\CAD\Plan_Sheets\Communications\West Corridor\1081211-sh-c-comm-trunk-02_KHA.dgn

TRUNK CABLE FIBER ASSIGNMENTS				ORIGINATION	CAB-NO-011C (IDOT COMMUNICATIONS NODE)		
TRUNK CABLE DESIGNATION			TCF-NO-003	DESTINATION	CAB-NO-017C (IDOT COMMUNICATIONS NODE)		
BUFFER TUBE	FIBER	FIBER NO.	ASSIGNMENT	BUFFER TUBE	FIBER	FIBER NO.	ASSIGNMENT
BLUE	Blue 1	1	IL 53 NODE CABINET TO I-290 NODE CABINET (10G LINK)	RED	Blue 1	73	DARK
	Orange 2	2	DARK		Orange 2	74	DARK
	Green 3	3	IL 59 NODE CABINET TO NORDIC TOWER CORE SWITCH (10G LINK)		Green 3	75	DARK
	Brown 4	4	DARK		Brown 4	76	DARK
	Slate 5	5	IL 59 NODE CABINET TO HILLSIDE TOWER CORE SWITCH (10G LINK)		Slate 5	77	DARK
	White 6	6	DARK		White 6	78	DARK
	Red 7	7	DARK		Red 7	79	DARK
	Black 8	8	DARK		Black 8	80	DARK
	Yellow 9	9	DARK		Yellow 9	81	DARK
	Violet 10	10	DARK		Violet 10	82	DARK
	Rose 11	11	DARK		Rose 11	83	DARK
	Aqua 12	12	DARK		Aqua 12	84	DARK
ORANGE	Blue 1	13	DARK	BLACK	Blue 1	85	DARK
	Orange 2	14	DARK		Orange 2	86	DARK
	Green 3	15	DARK		Green 3	87	DARK
	Brown 4	16	DARK		Brown 4	88	DARK
	Slate 5	17	DARK		Slate 5	89	DARK
	White 6	18	DARK		White 6	90	DARK
	Red 7	19	DARK		Red 7	91	DARK
	Black 8	20	DARK		Black 8	92	DARK
	Yellow 9	21	DARK		Yellow 9	93	DARK
	Violet 10	22	DARK		Violet 10	94	DARK
	Rose 11	23	DARK		Rose 11	95	DARK
	Aqua 12	24	DARK		Aqua 12	96	DARK
GREEN	Blue 1	25	DARK	YELLOW	Blue 1	97	DARK
	Orange 2	26	DARK		Orange 2	98	DARK
	Green 3	27	DARK		Green 3	99	DARK
	Brown 4	28	DARK		Brown 4	100	DARK
	Slate 5	29	DARK		Slate 5	101	DARK
	White 6	30	DARK		White 6	102	DARK
	Red 7	31	DARK		Red 7	103	DARK
	Black 8	32	DARK		Black 8	104	DARK
	Yellow 9	33	DARK		Yellow 9	105	DARK
	Violet 10	34	DARK		Violet 10	106	DARK
	Rose 11	35	DARK		Rose 11	107	DARK
	Aqua 12	36	DARK		Aqua 12	108	DARK
BROWN	Blue 1	37	DARK	VIOLET	Blue 1	109	DARK
	Orange 2	38	DARK		Orange 2	110	DARK
	Green 3	39	DARK		Green 3	111	DARK
	Brown 4	40	DARK		Brown 4	112	DARK
	Slate 5	41	DARK		Slate 5	113	DARK
	White 6	42	DARK		White 6	114	DARK
	Red 7	43	DARK		Red 7	115	DARK
	Black 8	44	DARK		Black 8	116	DARK
	Yellow 9	45	DARK		Yellow 9	117	DARK
	Violet 10	46	DARK		Violet 10	118	DARK
	Rose 11	47	DARK		Rose 11	119	DARK
	Aqua 12	48	DARK		Aqua 12	120	DARK
SLATE	Blue 1	49	DARK	ROSE	Blue 1	121	DARK
	Orange 2	50	DARK		Orange 2	122	DARK
	Green 3	51	DARK		Green 3	123	DARK
	Brown 4	52	DARK		Brown 4	124	DARK
	Slate 5	53	DARK		Slate 5	125	DARK
	White 6	54	DARK		White 6	126	DARK
	Red 7	55	DARK		Red 7	127	DARK
	Black 8	56	DARK		Black 8	128	DARK
	Yellow 9	57	DARK		Yellow 9	129	DARK
	Violet 10	58	DARK		Violet 10	130	DARK
	Rose 11	59	DARK		Rose 11	131	DARK
	Aqua 12	60	DARK		Aqua 12	132	DARK
WHITE	Blue 1	61	DARK	AQUA	Blue 1	133	DARK
	Orange 2	62	DARK		Orange 2	134	DARK
	Green 3	63	DARK		Green 3	135	DARK
	Brown 4	64	DARK		Brown 4	136	DARK
	Slate 5	65	DARK		Slate 5	137	DARK
	White 6	66	DARK		White 6	138	DARK
	Red 7	67	DARK		Red 7	139	DARK
	Black 8	68	DARK		Black 8	140	DARK
	Yellow 9	69	DARK		Yellow 9	141	DARK
	Violet 10	70	DARK		Violet 10	142	DARK
	Rose 11	71	DARK		Rose 11	143	DARK
	Aqua 12	72	DARK		Aqua 12	144	DARK



© 2023 KIMLEY-HORN AND ASSOCIATES, INC.
4001 HWY 10 ROAD, SUITE 400
WARREN, IL 60555
PHONE: 815.447.4555
WWW.KH-IL.COM

USER NAME =	DESIGNED -	REVISED -
	DRAWN -	REVISED -
PLOT SCALE =	CHECKED -	REVISED -
PLOT DATE =	DATE -	REVISED -

STATE OF ILLINOIS
DEPARTMENT OF TRANSPORTATION

FIBER OPTIC TRUNK CABLE SPLICE ASSIGNMENTS			
TCF-NO-003			
SCALE:	SHEET	OF	SHEETS
STA.		TO STA.	

F.A.P. RTE.	SECTION	COUNTY	TOTAL SHEETS	SHEET NO.
307	2020-263-SUR,SW&TS	DUPAGE	529	437
CONTRACT NO. 62N33				
ILLINOIS		FED. AID PROJECT		

MODEL: Default
FILE: \\usfpc-prod\hwy-bentley.com\khp-gp-d\Documents\01 Active Projects\MW-CUS-16895\100 - IL 54\Phase II\2 Design\CAD\Plan_Sheets\Communications\West Corridor\108121-54ht-comm-dst-01.khs.dgn

DISTRIBUTION CABLE FIBER ASSIGNMENTS				ORIGINATION	CAB-NO-000 (SMITH RD / KAUTZ RD TRAFFC SIGNAL CABINET)		
DISTRIBUTION CABLE DESIGNATION			DCF-NO-001	DESTINATION	CAB-NO-002E (IDOT COMMUNICATIONS NODE AT IL 59)		
BUFFER TUBE	FIBER	FIBER NO.	ASSIGNMENT	BUFFER TUBE	FIBER	FIBER NO.	ASSIGNMENT
BLUE	Blue	1	TRAFFIC SIGNAL CONTROLLER CABINET CAB-NO-000	RED	Blue	1	73 DARK
	Orange	2	TRAFFIC SIGNAL CONTROLLER CABINET CAB-NO-000		Orange	2	74 DARK
	Green	3	TRAFFIC SIGNAL CONTROLLER CABINET CAB-NO-000A		Green	3	75 DARK
	Brown	4	TRAFFIC SIGNAL CONTROLLER CABINET CAB-NO-000A		Brown	4	76 DARK
	Slate	5	TRAFFIC SIGNAL CONTROLLER CABINET CAB-NO-001		Slate	5	77 DARK
	White	6	TRAFFIC SIGNAL CONTROLLER CABINET CAB-NO-001		White	6	78 DARK
	Red	7	TRAFFIC SIGNAL CONTROLLER CABINET CAB-NO-002		Red	7	79 DARK
	Black	8	TRAFFIC SIGNAL CONTROLLER CABINET CAB-NO-002		Black	8	80 DARK
	Yellow	9	TRAFFIC SIGNAL CONTROLLER CABINET CAB-NO-002A		Yellow	9	81 DARK
	Violet	10	TRAFFIC SIGNAL CONTROLLER CABINET CAB-NO-002A		Violet	10	82 DARK
	Rose	11	TRAFFIC SIGNAL CONTROLLER CABINET CAB-NO-002B		Rose	11	83 DARK
	Aqua	12	TRAFFIC SIGNAL CONTROLLER CABINET CAB-NO-002B		Aqua	12	84 DARK
ORANGE	Blue	1	DARK	BLACK	Blue	1	85 DARK
	Orange	2	DARK		Orange	2	86 DARK
	Green	3	DARK		Green	3	87 DARK
	Brown	4	DARK		Brown	4	88 DARK
	Slate	5	DARK		Slate	5	89 DARK
	White	6	DARK		White	6	90 DARK
	Red	7	DARK		Red	7	91 DARK
	Black	8	DARK		Black	8	92 DARK
	Yellow	9	DARK		Yellow	9	93 DARK
	Violet	10	DARK		Violet	10	94 DARK
	Rose	11	DARK		Rose	11	95 DARK
	Aqua	12	DARK		Aqua	12	96 DARK
GREEN	Blue	1	DARK	YELLOW	Blue	1	97 DARK
	Orange	2	DARK		Orange	2	98 DARK
	Green	3	DARK		Green	3	99 DARK
	Brown	4	DARK		Brown	4	100 DARK
	Slate	5	DARK		Slate	5	101 DARK
	White	6	DARK		White	6	102 DARK
	Red	7	DARK		Red	7	103 DARK
	Black	8	DARK		Black	8	104 DARK
	Yellow	9	DARK		Yellow	9	105 DARK
	Violet	10	DARK		Violet	10	106 DARK
	Rose	11	DARK		Rose	11	107 DARK
	Aqua	12	DARK		Aqua	12	108 DARK
BROWN	Blue	1	DARK	VIOLET	Blue	1	109 DARK
	Orange	2	DARK		Orange	2	110 DARK
	Green	3	DARK		Green	3	111 DARK
	Brown	4	DARK		Brown	4	112 DARK
	Slate	5	DARK		Slate	5	113 DARK
	White	6	DARK		White	6	114 DARK
	Red	7	DARK		Red	7	115 DARK
	Black	8	DARK		Black	8	116 DARK
	Yellow	9	DARK		Yellow	9	117 DARK
	Violet	10	DARK		Violet	10	118 DARK
	Rose	11	DARK		Rose	11	119 DARK
	Aqua	12	DARK		Aqua	12	120 DARK
SLATE	Blue	1	DARK	ROSE	Blue	1	121 DARK
	Orange	2	DARK		Orange	2	122 DARK
	Green	3	DARK		Green	3	123 DARK
	Brown	4	DARK		Brown	4	124 DARK
	Slate	5	DARK		Slate	5	125 DARK
	White	6	DARK		White	6	126 DARK
	Red	7	SMITH RD / KAUTZ RD LAYER III SWITCH TO IL 59 CORE SWITCH (10G LINK)		Red	7	127 DARK
	Black	8	DARK		Black	8	128 DARK
	Yellow	9	DARK		Yellow	9	129 DARK
	Violet	10	DARK		Violet	10	130 DARK
	Rose	11	DARK		Rose	11	131 DARK
	Aqua	12	DARK		Aqua	12	132 DARK
WHITE	Blue	1	DARK	AQUA	Blue	1	133 DARK
	Orange	2	DARK		Orange	2	134 DARK
	Green	3	DARK		Green	3	135 DARK
	Brown	4	DARK		Brown	4	136 DARK
	Slate	5	DARK		Slate	5	137 DARK
	White	6	DARK		White	6	138 DARK
	Red	7	DARK		Red	7	139 DARK
	Black	8	DARK		Black	8	140 DARK
	Yellow	9	DARK		Yellow	9	141 DARK
	Violet	10	DARK		Violet	10	142 DARK
	Rose	11	DARK		Rose	11	143 DARK
	Aqua	12	DARK		Aqua	12	144 DARK



© 2023 KIMLEY-HORN AND ASSOCIATES, INC.
4001 HWY 10 ROAD, SUITE 600
WARREN, IL 6 0555
PHONE: 815.447.4555
WWW.KIMLEY-HORN.COM

USER NAME =	DESIGNED -	REVISED -
	DRAWN -	REVISED -
PLOT SCALE =	CHECKED -	REVISED -
PLOT DATE =	DATE -	REVISED -

STATE OF ILLINOIS
DEPARTMENT OF TRANSPORTATION

FIBER OPTIC DISTRIBUTION CABLE SPLICE ASSIGNMENTS
DCF-NO-001

SCALE: SHEET OF SHEETS STA. TO STA.

F.A.P. RTE.	SECTION	COUNTY	TOTAL SHEETS	SHEET NO.
307	2020-263-SUR,SW&TS	DUPAGE	529	438
CONTRACT NO. 62N33				
ILLINOIS		FED. AID PROJECT		

MODEL: Default
FILE: \\ntc-01\ntc-pw-bentley.com\khpw-d1\Documents\01 Active Projects\MW-CIS-16895\100 - IL 54\Phase II\2 Design\CAD\Plan_Sheets\Communications\West Corridor\108121-54ht-comm-dcf-02_41a.dgn

DISTRIBUTION CABLE FIBER ASSIGNMENTS				ORIGINATION	CAB-NO-000 (SMITH RD / KAUTZ RD TRAFFC SIGNAL CABINET)		
DISTRIBUTION CABLE DESIGNATION			DCF-NO-001	DESTINATION	CAB-NO-002E (IDOT COMMUNICATIONS NODE AT IL 59)		
BUFFER TUBE	FIBER	FIBER NO.	ASSIGNMENT	BUFFER TUBE	FIBER	FIBER NO.	ASSIGNMENT
BLUE	Blue	1	TRAFFIC SIGNAL CONTROLLER CABINET CAB-NO-000	RED	Blue	1	73 DARK
	Orange	2	TRAFFIC SIGNAL CONTROLLER CABINET CAB-NO-000		Orange	2	74 DARK
	Green	3	TRAFFIC SIGNAL CONTROLLER CABINET CAB-NO-000A		Green	3	75 DARK
	Brown	4	TRAFFIC SIGNAL CONTROLLER CABINET CAB-NO-000A		Brown	4	76 DARK
	Slate	5	TRAFFIC SIGNAL CONTROLLER CABINET CAB-NO-001		Slate	5	77 DARK
	White	6	TRAFFIC SIGNAL CONTROLLER CABINET CAB-NO-001		White	6	78 DARK
	Red	7	TRAFFIC SIGNAL CONTROLLER CABINET CAB-NO-002		Red	7	79 DARK
	Black	8	TRAFFIC SIGNAL CONTROLLER CABINET CAB-NO-002		Black	8	80 DARK
	Yellow	9	TRAFFIC SIGNAL CONTROLLER CABINET CAB-NO-002A		Yellow	9	81 DARK
	Violet	10	TRAFFIC SIGNAL CONTROLLER CABINET CAB-NO-002A		Violet	10	82 DARK
	Rose	11	TRAFFIC SIGNAL CONTROLLER CABINET CAB-NO-002B		Rose	11	83 DARK
	Aqua	12	TRAFFIC SIGNAL CONTROLLER CABINET CAB-NO-002B		Aqua	12	84 DARK
ORANGE	Blue	1	DARK	BLACK	Blue	1	85 DARK
	Orange	2	DARK		Orange	2	86 DARK
	Green	3	DARK		Green	3	87 DARK
	Brown	4	DARK		Brown	4	88 DARK
	Slate	5	DARK		Slate	5	89 DARK
	White	6	DARK		White	6	90 DARK
	Red	7	DARK		Red	7	91 DARK
	Black	8	DARK		Black	8	92 DARK
	Yellow	9	DARK		Yellow	9	93 DARK
	Violet	10	DARK		Violet	10	94 DARK
	Rose	11	DARK		Rose	11	95 DARK
	Aqua	12	DARK		Aqua	12	96 DARK
GREEN	Blue	1	DARK	YELLOW	Blue	1	97 DARK
	Orange	2	DARK		Orange	2	98 DARK
	Green	3	DARK		Green	3	99 DARK
	Brown	4	DARK		Brown	4	100 DARK
	Slate	5	DARK		Slate	5	101 DARK
	White	6	DARK		White	6	102 DARK
	Red	7	DARK		Red	7	103 DARK
	Black	8	DARK		Black	8	104 DARK
	Yellow	9	DARK		Yellow	9	105 DARK
	Violet	10	DARK		Violet	10	106 DARK
	Rose	11	DARK		Rose	11	107 DARK
	Aqua	12	DARK		Aqua	12	108 DARK
BROWN	Blue	1	DARK	VIOLET	Blue	1	109 DARK
	Orange	2	DARK		Orange	2	110 DARK
	Green	3	DARK		Green	3	111 DARK
	Brown	4	DARK		Brown	4	112 DARK
	Slate	5	DARK		Slate	5	113 DARK
	White	6	DARK		White	6	114 DARK
	Red	7	DARK		Red	7	115 DARK
	Black	8	DARK		Black	8	116 DARK
	Yellow	9	DARK		Yellow	9	117 DARK
	Violet	10	DARK		Violet	10	118 DARK
	Rose	11	DARK		Rose	11	119 DARK
	Aqua	12	DARK		Aqua	12	120 DARK
SLATE	Blue	1	DARK	ROSE	Blue	1	121 DARK
	Orange	2	DARK		Orange	2	122 DARK
	Green	3	DARK		Green	3	123 DARK
	Brown	4	DARK		Brown	4	124 DARK
	Slate	5	DARK		Slate	5	125 DARK
	White	6	DARK		White	6	126 DARK
	Red	7	SMITH RD / KAUTZ RD LAYER III SWITCH TO IL 59 CORE SWITCH (10G LINK)		Red	7	127 DARK
	Black	8	DARK		Black	8	128 DARK
	Yellow	9	DARK		Yellow	9	129 DARK
	Violet	10	DARK		Violet	10	130 DARK
	Rose	11	DARK		Rose	11	131 DARK
	Aqua	12	DARK		Aqua	12	132 DARK
WHITE	Blue	1	DARK	AQUA	Blue	1	133 DARK
	Orange	2	DARK		Orange	2	134 DARK
	Green	3	DARK		Green	3	135 DARK
	Brown	4	DARK		Brown	4	136 DARK
	Slate	5	DARK		Slate	5	137 DARK
	White	6	DARK		White	6	138 DARK
	Red	7	DARK		Red	7	139 DARK
	Black	8	DARK		Black	8	140 DARK
	Yellow	9	DARK		Yellow	9	141 DARK
	Violet	10	DARK		Violet	10	142 DARK
	Rose	11	DARK		Rose	11	143 DARK
	Aqua	12	DARK		Aqua	12	144 DARK



© 2023 KIMLEY-HORN AND ASSOCIATES, INC.
4001 HWY 10 ROAD, SUITE 600
WARREN, IL 6 0555
PHONE: 630.477.4555
WWW.KIMLEY-HORN.COM

USER NAME =	DESIGNED -	REVISED -
	DRAWN -	REVISED -
PLOT SCALE =	CHECKED -	REVISED -
PLOT DATE =	DATE -	REVISED -

STATE OF ILLINOIS
DEPARTMENT OF TRANSPORTATION

FIBER OPTIC DISTRIBUTION CABLE SPLICE ASSIGNMENTS			
DCF-NO-002			
SCALE:	SHEET	OF	SHEETS
STA.		TO STA.	

F.A.P. RTE.	SECTION	COUNTY	TOTAL SHEETS	SHEET NO.
307	2020-263-SUR,SW&TS	DUPAGE	529	439
CONTRACT NO. 62N33				
ILLINOIS		FED. AID PROJECT		

DISTRIBUTION CABLE FIBER ASSIGNMENTS				ORIGINATION	CAB-NO-011E (IDOT COMMUNICATIONS NODE AT IL 53)		
DISTRIBUTION CABLE DESIGNATION			DCF-NO-003	DESTINATION	CAB-NO-017C (IDOT COMMUNICATIONS NODE AT I-290)		
BUFFER TUBE	FIBER	FIBER NO.	ASSIGNMENT	BUFFER TUBE	FIBER	FIBER NO.	ASSIGNMENT
BLUE	Blue 1	1	DARK	RED	Blue 1	73	DARK
	Orange 2	2	DARK		Orange 2	74	DARK
	Green 3	3	DARK		Green 3	75	DARK
	Brown 4	4	DARK		Brown 4	76	DARK
	Slate 5	5	DARK		Slate 5	77	DARK
	White 6	6	DARK		White 6	78	DARK
	Red 7	7	DARK		Red 7	79	DARK
	Black 8	8	DARK		Black 8	80	DARK
	Yellow 9	9	TRAFFIC SIGNAL CONTROLLER CABINET CAB-NO-016		Yellow 9	81	DARK
	Violet 10	10	TRAFFIC SIGNAL CONTROLLER CABINET CAB-NO-016		Violet 10	82	DARK
	Rose 11	11	TRAFFIC SIGNAL CONTROLLER CABINET CAB-NO-016A		Rose 11	83	DARK
	Aqua 12	12	TRAFFIC SIGNAL CONTROLLER CABINET CAB-NO-016A		Aqua 12	84	DARK
ORANGE	Blue 1	13	TRAFFIC SIGNAL CONTROLLER CABINET CAB-NO-012A	BLACK	Blue 1	85	DARK
	Orange 2	14	TRAFFIC SIGNAL CONTROLLER CABINET CAB-NO-012A		Orange 2	86	DARK
	Green 3	15	TRAFFIC SIGNAL CONTROLLER CABINET CAB-NO-012B		Green 3	87	DARK
	Brown 4	16	TRAFFIC SIGNAL CONTROLLER CABINET CAB-NO-012B		Brown 4	88	DARK
	Slate 5	17	TRAFFIC SIGNAL CONTROLLER CABINET CAB-NO-013		Slate 5	89	DARK
	White 6	18	TRAFFIC SIGNAL CONTROLLER CABINET CAB-NO-013		White 6	90	DARK
	Red 7	19	TRAFFIC SIGNAL CONTROLLER CABINET CAB-NO-013A		Red 7	91	DARK
	Black 8	20	TRAFFIC SIGNAL CONTROLLER CABINET CAB-NO-013A		Black 8	92	DARK
	Yellow 9	21	TRAFFIC SIGNAL CONTROLLER CABINET CAB-NO-013B		Yellow 9	93	DARK
	Violet 10	22	TRAFFIC SIGNAL CONTROLLER CABINET CAB-NO-013B		Violet 10	94	DARK
	Rose 11	23	TRAFFIC SIGNAL CONTROLLER CABINET CAB-NO-014		Rose 11	95	DARK
	Aqua 12	24	TRAFFIC SIGNAL CONTROLLER CABINET CAB-NO-014		Aqua 12	96	DARK
GREEN	Blue 1	25	TRAFFIC SIGNAL CONTROLLER CABINET CAB-NO-014A	YELLOW	Blue 1	97	DARK
	Orange 2	26	TRAFFIC SIGNAL CONTROLLER CABINET CAB-NO-014A		Orange 2	98	DARK
	Green 3	27	TRAFFIC SIGNAL CONTROLLER CABINET CAB-NO-014B		Green 3	99	DARK
	Brown 4	28	TRAFFIC SIGNAL CONTROLLER CABINET CAB-NO-014B		Brown 4	100	DARK
	Slate 5	29	TRAFFIC SIGNAL CONTROLLER CABINET CAB-NO-015		Slate 5	101	DARK
	White 6	30	TRAFFIC SIGNAL CONTROLLER CABINET CAB-NO-015		White 6	102	DARK
	Red 7	31	TRAFFIC SIGNAL CONTROLLER CABINET CAB-NO-015A		Red 7	103	DARK
	Black 8	32	TRAFFIC SIGNAL CONTROLLER CABINET CAB-NO-015A		Black 8	104	DARK
	Yellow 9	33	TRAFFIC SIGNAL CONTROLLER CABINET CAB-NO-015B		Yellow 9	105	DARK
	Violet 10	34	TRAFFIC SIGNAL CONTROLLER CABINET CAB-NO-015B		Violet 10	106	DARK
	Rose 11	35	TRAFFIC SIGNAL CONTROLLER CABINET CAB-NO-015C		Rose 11	107	DARK
	Aqua 12	36	TRAFFIC SIGNAL CONTROLLER CABINET CAB-NO-015C		Aqua 12	108	DARK
BROWN	Blue 1	37	DMS-NO-012	VIOLET	Blue 1	109	DARK
	Orange 2	38	DMS-NO-012		Orange 2	110	DARK
	Green 3	39	DMS-NO-014		Green 3	111	DARK
	Brown 4	40	DMS-NO-014		Brown 4	112	DARK
	Slate 5	41	DARK		Slate 5	113	DARK
	White 6	42	DARK		White 6	114	DARK
	Red 7	43	DARK		Red 7	115	DARK
	Black 8	44	DARK		Black 8	116	DARK
	Yellow 9	45	DARK		Yellow 9	117	DARK
	Violet 10	46	DARK		Violet 10	118	DARK
	Rose 11	47	DARK		Rose 11	119	DARK
	Aqua 12	48	DARK		Aqua 12	120	DARK
SLATE	Blue 1	49	IL 59 CORE SWITCH SMITH TO I-290 CORE SWITCH (10G LINK)	ROSE	Blue 1	121	DARK
	Orange 2	50	DARK		Orange 2	122	DARK
	Green 3	51	DARK		Green 3	123	DARK
	Brown 4	52	DARK		Brown 4	124	DARK
	Slate 5	53	DARK		Slate 5	125	DARK
	White 6	54	DARK		White 6	126	DARK
	Red 7	55	IL 59 CORE SWITCH SMITH TO I-290 CORE SWITCH (10G LINK)		Red 7	127	DARK
	Black 8	56	DARK		Black 8	128	DARK
	Yellow 9	57	DARK		Yellow 9	129	DARK
	Violet 10	58	DARK		Violet 10	130	DARK
	Rose 11	59	DARK		Rose 11	131	DARK
	Aqua 12	60	DARK		Aqua 12	132	DARK
WHITE	Blue 1	61	DARK	AQUA	Blue 1	133	DARK
	Orange 2	62	DARK		Orange 2	134	DARK
	Green 3	63	DARK		Green 3	135	DARK
	Brown 4	64	DARK		Brown 4	136	DARK
	Slate 5	65	DARK		Slate 5	137	DARK
	White 6	66	DARK		White 6	138	DARK
	Red 7	67	DARK		Red 7	139	DARK
	Black 8	68	DARK		Black 8	140	DARK
	Yellow 9	69	DARK		Yellow 9	141	DARK
	Violet 10	70	DARK		Violet 10	142	DARK
	Rose 11	71	DARK		Rose 11	143	DARK
	Aqua 12	72	DARK		Aqua 12	144	DARK

 © 2023 KIMLEY-HORN AND ASSOCIATES, INC. 4001 S. WILSON, D. ROAD, SUITE 600 WARRICK, I.E. 46085 PHONE: 317-847-6000 WWW.KH-ELY-HORN.COM	USER NAME =	DESIGNED -	REVISED -	STATE OF ILLINOIS DEPARTMENT OF TRANSPORTATION	FIBER OPTIC DISTRIBUTION CABLE SPLICE ASSIGNMENTS DCF-NO-003					F.A.P. RTE.	SECTION	COUNTY	TOTAL SHEETS	SHEET NO.
	PLOT SCALE =	CHECKED -	REVISED -							307	2020-263-SUR, SW&TS	DUPAGE	529	440
	PLOT DATE =	DATE -	REVISED -		SCALE: SHEET OF SHEETS STA. TO STA.					CONTRACT NO. 62N33				

LATERAL CABLE FIBER ASSIGNMENTS				ORIGINATION	CAB-NO-000
LATERAL CABLE DESIGNATION		LCF-NO-001a		DESTINATION	CMV-NO-000
BUFFER TUBE	FIBER	FIBER NO.	CABINET CONNECTIONS	DISTRIBUTION CABLE CONNECTIONS	
BLUE	Blue 1	1	PATCH PANEL "A" PORT 1 (JUMPERED TO LAYER III ETHERNET SWITCH)	DCF-NO-001 (EB), FIBER 1	
	Orange 2	2	PATCH PANEL "A" PORT 2 (JUMPERED TO LAYER III ETHERNET SWITCH)	DCF-NO-001 (EB), FIBER 2	
	Green 3	3	PATCH PANEL "A" PORT 3	NO CONNECTION (LATERAL STRANDS COILED IN SPLICE CLOSURE)	
	Brown 4	4	PATCH PANEL "A" PORT 4	NO CONNECTION (LATERAL STRANDS COILED IN SPLICE CLOSURE)	
	Slate 5	5	PATCH PANEL "A" PORT 5	NO CONNECTION (LATERAL STRANDS COILED IN SPLICE CLOSURE)	
	White 6	6	PATCH PANEL "A" PORT 6	NO CONNECTION (LATERAL STRANDS COILED IN SPLICE CLOSURE)	
	Red 7	7	PATCH PANEL "A" PORT 7 (JUMPERED TO LAYER III ETHERNET SWITCH)	DCF-NO-001 (EB), FIBER 55	
	Black 8	8	PATCH PANEL "A" PORT 8	NO CONNECTION (LATERAL STRANDS COILED IN SPLICE CLOSURE)	
	Yellow 9	9	PATCH PANEL "A" PORT 9	NO CONNECTION (LATERAL STRANDS COILED IN SPLICE CLOSURE)	
	Violet 10	10	PATCH PANEL "A" PORT 10	NO CONNECTION (LATERAL STRANDS COILED IN SPLICE CLOSURE)	
	Rose 11	11	PATCH PANEL "A" PORT 11	NO CONNECTION (LATERAL STRANDS COILED IN SPLICE CLOSURE)	
	Aqua 12	12	PATCH PANEL "A" PORT 12	NO CONNECTION (LATERAL STRANDS COILED IN SPLICE CLOSURE)	
ORANGE	Blue 1	13	COILED IN FIBER OPTIC INTERCONNECT CENTER	NO CONNECTION (LATERAL STRANDS COILED IN SPLICE CLOSURE)	
	Orange 2	14	COILED IN FIBER OPTIC INTERCONNECT CENTER	NO CONNECTION (LATERAL STRANDS COILED IN SPLICE CLOSURE)	
	Green 3	15	COILED IN FIBER OPTIC INTERCONNECT CENTER	NO CONNECTION (LATERAL STRANDS COILED IN SPLICE CLOSURE)	
	Brown 4	16	COILED IN FIBER OPTIC INTERCONNECT CENTER	NO CONNECTION (LATERAL STRANDS COILED IN SPLICE CLOSURE)	
	Slate 5	17	COILED IN FIBER OPTIC INTERCONNECT CENTER	NO CONNECTION (LATERAL STRANDS COILED IN SPLICE CLOSURE)	
	White 6	18	COILED IN FIBER OPTIC INTERCONNECT CENTER	NO CONNECTION (LATERAL STRANDS COILED IN SPLICE CLOSURE)	
	Red 7	19	COILED IN FIBER OPTIC INTERCONNECT CENTER	NO CONNECTION (LATERAL STRANDS COILED IN SPLICE CLOSURE)	
	Black 8	20	COILED IN FIBER OPTIC INTERCONNECT CENTER	NO CONNECTION (LATERAL STRANDS COILED IN SPLICE CLOSURE)	
	Yellow 9	21	COILED IN FIBER OPTIC INTERCONNECT CENTER	NO CONNECTION (LATERAL STRANDS COILED IN SPLICE CLOSURE)	
	Violet 10	22	COILED IN FIBER OPTIC INTERCONNECT CENTER	NO CONNECTION (LATERAL STRANDS COILED IN SPLICE CLOSURE)	
	Rose 11	23	COILED IN FIBER OPTIC INTERCONNECT CENTER	NO CONNECTION (LATERAL STRANDS COILED IN SPLICE CLOSURE)	
	Aqua 12	24	COILED IN FIBER OPTIC INTERCONNECT CENTER	NO CONNECTION (LATERAL STRANDS COILED IN SPLICE CLOSURE)	

Kimley»Horn
© 2025 KIMLEY-HORN AND ASSOCIATES, INC.
4201 WHITEFIELD ROAD, SUITE 600
WARRENVILLE, IL 60555
PHONE: 630-487-6550
WWW.KIMLEY-HORN.COM

USER NAME =	DESIGNED -	REVISED -
	DRAWN -	REVISED -
PLOT SCALE =	CHECKED -	REVISED -
PLOT DATE =	DATE -	REVISED -

STATE OF ILLINOIS
DEPARTMENT OF TRANSPORTATION

FIBER OPTIC LATERAL CABLE SPLICE ASSIGNMENTS

LCF-NO-001a

SCALE:	SHEET	OF	SHEETS	STA.	TO STA.
--------	-------	----	--------	------	---------

F.A.P. RTE.	SECTION	COUNTY	TOTAL SHEETS	SHEET NO.
307	2020-263-SUR,SW&TS	DUPAGE	529	441
		CONTRACT NO. 62N33		
ILLINOIS		FED. AID PROJECT		

LATERAL CABLE FIBER ASSIGNMENTS				ORIGINATION	CAB-NO-000A
LATERAL CABLE DESIGNATION			LCF-NO-001b	DESTINATION	CMV-NO-000C
BUFFER TUBE	FIBER	FIBER NO.	CABINET CONNECTIONS	DISTRIBUTION CABLE CONNECTIONS	
BLUE	Blue	1	PATCH PANEL "A" PORT 1 (JUMPERED TO LAYER II ETHERNET SWITCH)	DCF-NO-001 (WB), FIBER 3	
	Orange	2	PATCH PANEL "A" PORT 2 (JUMPERED TO LAYER II ETHERNET SWITCH)	DCF-NO-001 (WB), FIBER 4	
	Green	3	PATCH PANEL "A" PORT 3	NO CONNECTION (LATERAL STRANDS COILED IN SPLICE CLOSURE)	
	Brown	4	PATCH PANEL "A" PORT 4	NO CONNECTION (LATERAL STRANDS COILED IN SPLICE CLOSURE)	
	Slate	5	PATCH PANEL "A" PORT 5	NO CONNECTION (LATERAL STRANDS COILED IN SPLICE CLOSURE)	
	White	6	PATCH PANEL "A" PORT 6	NO CONNECTION (LATERAL STRANDS COILED IN SPLICE CLOSURE)	
	Red	7	PATCH PANEL "A" PORT 7 (JUMPERED TO LAYER II ETHERNET SWITCH)	DCF-NO-001 (EB), FIBER 3	
	Black	8	PATCH PANEL "A" PORT 8 (JUMPERED TO LAYER II ETHERNET SWITCH)	DCF-NO-001 (EB), FIBER 4	
	Yellow	9	PATCH PANEL "A" PORT 9	NO CONNECTION (LATERAL STRANDS COILED IN SPLICE CLOSURE)	
	Violet	10	PATCH PANEL "A" PORT 10	NO CONNECTION (LATERAL STRANDS COILED IN SPLICE CLOSURE)	
	Rose	11	PATCH PANEL "A" PORT 11	NO CONNECTION (LATERAL STRANDS COILED IN SPLICE CLOSURE)	
	Aqua	12	PATCH PANEL "A" PORT 12	NO CONNECTION (LATERAL STRANDS COILED IN SPLICE CLOSURE)	
ORANGE	Blue	13	COILED IN FIBER OPTIC INTERCONNECT CENTER	NO CONNECTION (LATERAL STRANDS COILED IN SPLICE CLOSURE)	
	Orange	14	COILED IN FIBER OPTIC INTERCONNECT CENTER	NO CONNECTION (LATERAL STRANDS COILED IN SPLICE CLOSURE)	
	Green	15	COILED IN FIBER OPTIC INTERCONNECT CENTER	NO CONNECTION (LATERAL STRANDS COILED IN SPLICE CLOSURE)	
	Brown	16	COILED IN FIBER OPTIC INTERCONNECT CENTER	NO CONNECTION (LATERAL STRANDS COILED IN SPLICE CLOSURE)	
	Slate	17	COILED IN FIBER OPTIC INTERCONNECT CENTER	NO CONNECTION (LATERAL STRANDS COILED IN SPLICE CLOSURE)	
	White	18	COILED IN FIBER OPTIC INTERCONNECT CENTER	NO CONNECTION (LATERAL STRANDS COILED IN SPLICE CLOSURE)	
	Red	19	COILED IN FIBER OPTIC INTERCONNECT CENTER	NO CONNECTION (LATERAL STRANDS COILED IN SPLICE CLOSURE)	
	Black	20	COILED IN FIBER OPTIC INTERCONNECT CENTER	NO CONNECTION (LATERAL STRANDS COILED IN SPLICE CLOSURE)	
	Yellow	21	COILED IN FIBER OPTIC INTERCONNECT CENTER	NO CONNECTION (LATERAL STRANDS COILED IN SPLICE CLOSURE)	
	Violet	10	COILED IN FIBER OPTIC INTERCONNECT CENTER	NO CONNECTION (LATERAL STRANDS COILED IN SPLICE CLOSURE)	
	Rose	11	COILED IN FIBER OPTIC INTERCONNECT CENTER	NO CONNECTION (LATERAL STRANDS COILED IN SPLICE CLOSURE)	
	Aqua	12	COILED IN FIBER OPTIC INTERCONNECT CENTER	NO CONNECTION (LATERAL STRANDS COILED IN SPLICE CLOSURE)	

 © 2022 KIMLEY-HORN AND ASSOCIATES, INC. 4301 WARREN C. ROAD, SUITE 400 WARREN, ILL. 60555 PHONE: 630-454-6000 WWW.KIMLEY-HORN.COM	USER NAME =	DESIGNED -	REVISED -	STATE OF ILLINOIS DEPARTMENT OF TRANSPORTATION	FIBER OPTIC LATERAL CABLE SPLICE ASSIGNMENTS LCF-NO-001b					F.A.P. RTE.	SECTION	COUNTY	TOTAL SHEETS	SHEET NO.
	PLOT SCALE =	DRAWN -	REVISED -							307	2020-263-SUR, SW&TS	DUPAGE	529	442
	PLOT DATE =	CHECKED -	REVISED -		CONTRACT NO. 62N33									
	PLOT DATE =	DATE -	REVISED -		SCALE:	SHEET	OF	SHEETS	STA.	TO STA.	ILLINOIS	FED. AID PROJECT		

LATERAL CABLE FIBER ASSIGNMENTS				ORIGINATION	CAB-NO-002
LATERAL CABLE DESIGNATION			LCF-NO-001d	DESTINATION	CMV-NO-002A
BUFFER TUBE	FIBER	FIBER NO.	CABINET CONNECTIONS	DISTRIBUTION CABLE CONNECTIONS	
BLUE	Blue	1	PATCH PANEL "A" PORT 1 (JUMPERED TO LAYER II ETHERNET SWITCH)	DCF-NO-001 (WB), FIBER 7	
	Orange	2	PATCH PANEL "A" PORT 2 (JUMPERED TO LAYER II ETHERNET SWITCH)	DCF-NO-001 (WB), FIBER 8	
	Green	3	PATCH PANEL "A" PORT 3	NO CONNECTION (LATERAL STRANDS COILED IN SPLICE CLOSURE)	
	Brown	4	PATCH PANEL "A" PORT 4	NO CONNECTION (LATERAL STRANDS COILED IN SPLICE CLOSURE)	
	Slate	5	PATCH PANEL "A" PORT 5	NO CONNECTION (LATERAL STRANDS COILED IN SPLICE CLOSURE)	
	White	6	PATCH PANEL "A" PORT 6	NO CONNECTION (LATERAL STRANDS COILED IN SPLICE CLOSURE)	
	Red	7	PATCH PANEL "A" PORT 7 (JUMPERED TO LAYER II ETHERNET SWITCH)	DCF-NO-001 (EB), FIBER 7	
	Black	8	PATCH PANEL "A" PORT 8 (JUMPERED TO LAYER II ETHERNET SWITCH)	DCF-NO-001 (EB), FIBER 8	
	Yellow	9	PATCH PANEL "A" PORT 9	NO CONNECTION (LATERAL STRANDS COILED IN SPLICE CLOSURE)	
	Violet	10	PATCH PANEL "A" PORT 10	NO CONNECTION (LATERAL STRANDS COILED IN SPLICE CLOSURE)	
	Rose	11	PATCH PANEL "A" PORT 11	NO CONNECTION (LATERAL STRANDS COILED IN SPLICE CLOSURE)	
	Aqua	12	PATCH PANEL "A" PORT 12	NO CONNECTION (LATERAL STRANDS COILED IN SPLICE CLOSURE)	
ORANGE	Blue	13	COILED IN FIBER OPTIC INTERCONNECT CENTER	NO CONNECTION (LATERAL STRANDS COILED IN SPLICE CLOSURE)	
	Orange	14	COILED IN FIBER OPTIC INTERCONNECT CENTER	NO CONNECTION (LATERAL STRANDS COILED IN SPLICE CLOSURE)	
	Green	15	COILED IN FIBER OPTIC INTERCONNECT CENTER	NO CONNECTION (LATERAL STRANDS COILED IN SPLICE CLOSURE)	
	Brown	16	COILED IN FIBER OPTIC INTERCONNECT CENTER	NO CONNECTION (LATERAL STRANDS COILED IN SPLICE CLOSURE)	
	Slate	17	COILED IN FIBER OPTIC INTERCONNECT CENTER	NO CONNECTION (LATERAL STRANDS COILED IN SPLICE CLOSURE)	
	White	18	COILED IN FIBER OPTIC INTERCONNECT CENTER	NO CONNECTION (LATERAL STRANDS COILED IN SPLICE CLOSURE)	
	Red	19	COILED IN FIBER OPTIC INTERCONNECT CENTER	NO CONNECTION (LATERAL STRANDS COILED IN SPLICE CLOSURE)	
	Black	20	COILED IN FIBER OPTIC INTERCONNECT CENTER	NO CONNECTION (LATERAL STRANDS COILED IN SPLICE CLOSURE)	
	Yellow	21	COILED IN FIBER OPTIC INTERCONNECT CENTER	NO CONNECTION (LATERAL STRANDS COILED IN SPLICE CLOSURE)	
	Violet	10	COILED IN FIBER OPTIC INTERCONNECT CENTER	NO CONNECTION (LATERAL STRANDS COILED IN SPLICE CLOSURE)	
	Rose	11	COILED IN FIBER OPTIC INTERCONNECT CENTER	NO CONNECTION (LATERAL STRANDS COILED IN SPLICE CLOSURE)	
	Aqua	12	COILED IN FIBER OPTIC INTERCONNECT CENTER	NO CONNECTION (LATERAL STRANDS COILED IN SPLICE CLOSURE)	

 © 2022 KIMLEY-HORN AND ASSOCIATES, INC. 4001 WILHELM D. ROSS, SUITE 600 WARREN, IL 6 00655 PHONE: 634-877-0000 WWW.KIMLEY-HORN.COM	USER NAME =	DESIGNED -	REVISED -	STATE OF ILLINOIS DEPARTMENT OF TRANSPORTATION	FIBER OPTIC LATERAL CABLE SPLICE ASSIGNMENTS LCF-NO-001d					F.A.P. RTE.	SECTION	COUNTY	TOTAL SHEETS	SHEET NO.
	PLOT SCALE =	DRAWN -	REVISED -							307	2020-263-SUR,SW&TS	DUPAGE	529	444
	PLOT DATE =	CHECKED -	REVISED -		SCALE: SHEET OF SHEETS STA. TO STA.					CONTRACT NO. 62N33				
		DATE	REVISED -							ILLINOIS FED. AID PROJECT				

LATERAL CABLE FIBER ASSIGNMENTS				ORIGINATION	CAB-NO-004
LATERAL CABLE DESIGNATION			LCF-NO-002a	DESTINATION	CMV-NO-004A
BUFFER TUBE	FIBER	FIBER NO.	CABINET CONNECTIONS	DISTRIBUTION CABLE CONNECTIONS	
BLUE	Blue	1	PATCH PANEL "A" PORT 1 (JUMPERED TO LAYER II ETHERNET SWITCH)	DCF-NO-002 (WB), FIBER 1	
	Orange	2	PATCH PANEL "A" PORT 2 (JUMPERED TO LAYER II ETHERNET SWITCH)	DCF-NO-002 (WB), FIBER 2	
	Green	3	PATCH PANEL "A" PORT 3	NO CONNECTION (LATERAL STRANDS COILED IN SPLICE CLOSURE)	
	Brown	4	PATCH PANEL "A" PORT 4	NO CONNECTION (LATERAL STRANDS COILED IN SPLICE CLOSURE)	
	Slate	5	PATCH PANEL "A" PORT 5	NO CONNECTION (LATERAL STRANDS COILED IN SPLICE CLOSURE)	
	White	6	PATCH PANEL "A" PORT 6	NO CONNECTION (LATERAL STRANDS COILED IN SPLICE CLOSURE)	
	Red	7	PATCH PANEL "A" PORT 7 (JUMPERED TO LAYER II ETHERNET SWITCH)	DCF-NO-002 (EB), FIBER 1	
	Black	8	PATCH PANEL "A" PORT 8 (JUMPERED TO LAYER II ETHERNET SWITCH)	DCF-NO-002 (EB), FIBER 2	
	Yellow	9	PATCH PANEL "A" PORT 9	NO CONNECTION (LATERAL STRANDS COILED IN SPLICE CLOSURE)	
	Violet	10	PATCH PANEL "A" PORT 10	NO CONNECTION (LATERAL STRANDS COILED IN SPLICE CLOSURE)	
	Rose	11	PATCH PANEL "A" PORT 11	NO CONNECTION (LATERAL STRANDS COILED IN SPLICE CLOSURE)	
	Aqua	12	PATCH PANEL "A" PORT 12	NO CONNECTION (LATERAL STRANDS COILED IN SPLICE CLOSURE)	
ORANGE	Blue	13	COILED IN FIBER OPTIC INTERCONNECT CENTER	NO CONNECTION (LATERAL STRANDS COILED IN SPLICE CLOSURE)	
	Orange	14	COILED IN FIBER OPTIC INTERCONNECT CENTER	NO CONNECTION (LATERAL STRANDS COILED IN SPLICE CLOSURE)	
	Green	15	COILED IN FIBER OPTIC INTERCONNECT CENTER	NO CONNECTION (LATERAL STRANDS COILED IN SPLICE CLOSURE)	
	Brown	16	COILED IN FIBER OPTIC INTERCONNECT CENTER	NO CONNECTION (LATERAL STRANDS COILED IN SPLICE CLOSURE)	
	Slate	17	COILED IN FIBER OPTIC INTERCONNECT CENTER	NO CONNECTION (LATERAL STRANDS COILED IN SPLICE CLOSURE)	
	White	18	COILED IN FIBER OPTIC INTERCONNECT CENTER	NO CONNECTION (LATERAL STRANDS COILED IN SPLICE CLOSURE)	
	Red	19	COILED IN FIBER OPTIC INTERCONNECT CENTER	NO CONNECTION (LATERAL STRANDS COILED IN SPLICE CLOSURE)	
	Black	20	COILED IN FIBER OPTIC INTERCONNECT CENTER	NO CONNECTION (LATERAL STRANDS COILED IN SPLICE CLOSURE)	
	Yellow	21	COILED IN FIBER OPTIC INTERCONNECT CENTER	NO CONNECTION (LATERAL STRANDS COILED IN SPLICE CLOSURE)	
	Violet	10	COILED IN FIBER OPTIC INTERCONNECT CENTER	NO CONNECTION (LATERAL STRANDS COILED IN SPLICE CLOSURE)	
	Rose	11	COILED IN FIBER OPTIC INTERCONNECT CENTER	NO CONNECTION (LATERAL STRANDS COILED IN SPLICE CLOSURE)	
	Aqua	12	COILED IN FIBER OPTIC INTERCONNECT CENTER	NO CONNECTION (LATERAL STRANDS COILED IN SPLICE CLOSURE)	

 © 2022 KIMLEY-HORN AND ASSOCIATES, INC. 4001 WILHELM ROAD, SUITE 400 WARRENBURGE, IL 61085 PHONE: 630-462-6000 WWW.KIMLEY-HORN.COM	USER NAME =	DESIGNED -	REVISED -	STATE OF ILLINOIS DEPARTMENT OF TRANSPORTATION	FIBER OPTIC LATERAL CABLE SPLICE ASSIGNMENTS LCF-NO-002a					F.A.P. RTE.	SECTION	COUNTY	TOTAL SHEETS	SHEET NO.
	PLOT SCALE =	DRAWN -	REVISED -							307	2020-263-SUR, SW&TS	DUPAGE	529	445
	PLOT DATE =	CHECKED -	REVISED -		CONTRACT NO. 62N33									
		DATE -	REVISED -		SCALE:	SHEET	OF	SHEETS	STA.	TO STA.	ILLINOIS	FED. AID PROJECT		

Model: Default
File: Kimley-Horn\Bentley.com\k-h-gp-d\1\Documents\01 Active Projects\MW-CUS-16895\100 - IL 64\Phase 1\12 Design\CAD\Plan Sheets\Communications\West Corridor\108121-eh-cmm-lateral06.khm.dgn

LATERAL CABLE FIBER ASSIGNMENTS				ORIGINATION	CAB-NO-004A
LATERAL CABLE DESIGNATION			LCF-NO-002b	DESTINATION	CMV-NO-004E
BUFFER TUBE	FIBER	FIBER NO.	CABINET CONNECTIONS	DISTRIBUTION CABLE CONNECTIONS	
BLUE	Blue	1	1	PATCH PANEL "A" PORT 1 (JUMPERED TO LAYER II ETHERNET SWITCH)	DCF-NO-002 (WB), FIBER 3
	Orange	2	2	PATCH PANEL "A" PORT 2 (JUMPERED TO LAYER II ETHERNET SWITCH)	DCF-NO-002 (WB), FIBER 4
	Green	3	3	PATCH PANEL "A" PORT 3	NO CONNECTION (LATERAL STRANDS COILED IN SPLICE CLOSURE)
	Brown	4	4	PATCH PANEL "A" PORT 4	NO CONNECTION (LATERAL STRANDS COILED IN SPLICE CLOSURE)
	Slate	5	5	PATCH PANEL "A" PORT 5	NO CONNECTION (LATERAL STRANDS COILED IN SPLICE CLOSURE)
	White	6	6	PATCH PANEL "A" PORT 6	NO CONNECTION (LATERAL STRANDS COILED IN SPLICE CLOSURE)
	Red	7	7	PATCH PANEL "A" PORT 7 (JUMPERED TO LAYER II ETHERNET SWITCH)	DCF-NO-002 (EB), FIBER 3
	Black	8	8	PATCH PANEL "A" PORT 8 (JUMPERED TO LAYER II ETHERNET SWITCH)	DCF-NO-002 (EB), FIBER 4
	Yellow	9	9	PATCH PANEL "A" PORT 9	NO CONNECTION (LATERAL STRANDS COILED IN SPLICE CLOSURE)
	Violet	10	10	PATCH PANEL "A" PORT 10	NO CONNECTION (LATERAL STRANDS COILED IN SPLICE CLOSURE)
	Rose	11	11	PATCH PANEL "A" PORT 11	NO CONNECTION (LATERAL STRANDS COILED IN SPLICE CLOSURE)
	Aqua	12	12	PATCH PANEL "A" PORT 12	NO CONNECTION (LATERAL STRANDS COILED IN SPLICE CLOSURE)
ORANGE	Blue	1	13	COILED IN FIBER OPTIC INTERCONNECT CENTER	NO CONNECTION (LATERAL STRANDS COILED IN SPLICE CLOSURE)
	Orange	2	14	COILED IN FIBER OPTIC INTERCONNECT CENTER	NO CONNECTION (LATERAL STRANDS COILED IN SPLICE CLOSURE)
	Green	3	15	COILED IN FIBER OPTIC INTERCONNECT CENTER	NO CONNECTION (LATERAL STRANDS COILED IN SPLICE CLOSURE)
	Brown	4	16	COILED IN FIBER OPTIC INTERCONNECT CENTER	NO CONNECTION (LATERAL STRANDS COILED IN SPLICE CLOSURE)
	Slate	5	17	COILED IN FIBER OPTIC INTERCONNECT CENTER	NO CONNECTION (LATERAL STRANDS COILED IN SPLICE CLOSURE)
	White	6	18	COILED IN FIBER OPTIC INTERCONNECT CENTER	NO CONNECTION (LATERAL STRANDS COILED IN SPLICE CLOSURE)
	Red	7	19	COILED IN FIBER OPTIC INTERCONNECT CENTER	NO CONNECTION (LATERAL STRANDS COILED IN SPLICE CLOSURE)
	Black	8	20	COILED IN FIBER OPTIC INTERCONNECT CENTER	NO CONNECTION (LATERAL STRANDS COILED IN SPLICE CLOSURE)
	Yellow	9	21	COILED IN FIBER OPTIC INTERCONNECT CENTER	NO CONNECTION (LATERAL STRANDS COILED IN SPLICE CLOSURE)
	Violet	10	22	COILED IN FIBER OPTIC INTERCONNECT CENTER	NO CONNECTION (LATERAL STRANDS COILED IN SPLICE CLOSURE)
	Rose	11	23	COILED IN FIBER OPTIC INTERCONNECT CENTER	NO CONNECTION (LATERAL STRANDS COILED IN SPLICE CLOSURE)
	Aqua	12	24	COILED IN FIBER OPTIC INTERCONNECT CENTER	NO CONNECTION (LATERAL STRANDS COILED IN SPLICE CLOSURE)



© 2023 KIMLEY-HORN AND ASSOCIATES, INC.
4001 KIMLEY-HORN ROAD, SUITE 600
WARREN, IL 6. 60555
PHONE: 815.447.4555
WWW.KIMLEY-HORN.COM

USER NAME	=	
PLOT SCALE	=	
PLOT DATE	=	

DESIGNED	-	
DRAWN	-	
CHECKED	-	
DATE	-	

REVISED	-	
REVISED	-	
REVISED	-	
REVISED	-	

STATE OF ILLINOIS
DEPARTMENT OF TRANSPORTATION

FIBER OPTIC LATERAL CABLE SPLICE ASSIGNMENTS
LCF-NO-002b

SCALE:	SHEET	OF	SHEETS	STA.	TO	STA.
--------	-------	----	--------	------	----	------

F.A.P. RTE.	SECTION	COUNTY	TOTAL SHEETS	SHEET NO.
307	2020-263-SUR,SW&TS	DUPAGE	529	446
CONTRACT NO. 62N33				
ILLINOIS		FED. AID PROJECT		

LATERAL CABLE FIBER ASSIGNMENTS				ORIGINATION	CAB-NO-005
LATERAL CABLE DESIGNATION			LCF-NO-002c	DESTINATION	CMV-NO-005F
BUFFER TUBE	FIBER	FIBER NO.	CABINET CONNECTIONS	DISTRIBUTION CABLE CONNECTIONS	
BLUE	Blue	1	PATCH PANEL "A" PORT 1 (JUMPERED TO LAYER III ETHERNET SWITCH)	DCF-NO-002 (WB), FIBER 5	
	Orange	2	PATCH PANEL "A" PORT 2 (JUMPERED TO LAYER III ETHERNET SWITCH)	DCF-NO-002 (WB), FIBER 6	
	Green	3	PATCH PANEL "A" PORT 3	NO CONNECTION (LATERAL STRANDS COILED IN SPLICE CLOSURE)	
	Brown	4	PATCH PANEL "A" PORT 4	NO CONNECTION (LATERAL STRANDS COILED IN SPLICE CLOSURE)	
	Slate	5	PATCH PANEL "A" PORT 5	NO CONNECTION (LATERAL STRANDS COILED IN SPLICE CLOSURE)	
	White	6	PATCH PANEL "A" PORT 6	NO CONNECTION (LATERAL STRANDS COILED IN SPLICE CLOSURE)	
	Red	7	PATCH PANEL "A" PORT 7 (JUMPERED TO LAYER III ETHERNET SWITCH)	DCF-NO-002 (EB), FIBER 5	
	Black	8	PATCH PANEL "A" PORT 8 (JUMPERED TO LAYER II ETHERNET SWITCH)	DCF-NO-002 (EB), FIBER 6	
	Yellow	9	PATCH PANEL "A" PORT 9	NO CONNECTION (LATERAL STRANDS COILED IN SPLICE CLOSURE)	
	Violet	10	PATCH PANEL "A" PORT 10	NO CONNECTION (LATERAL STRANDS COILED IN SPLICE CLOSURE)	
	Rose	11	PATCH PANEL "A" PORT 11 (JUMPERED TO LAYER III ETHERNET SWITCH)	DCF-NO-002 (WB), FIBER 55	
	Aqua	12	PATCH PANEL "A" PORT 12 (JUMPERED TO LAYER III ETHERNET SWITCH)	DCF-NO-002 (EB), FIBER 55	
ORANGE	Blue	13	COILED IN FIBER OPTIC INTERCONNECT CENTER	NO CONNECTION (LATERAL STRANDS COILED IN SPLICE CLOSURE)	
	Orange	14	COILED IN FIBER OPTIC INTERCONNECT CENTER	NO CONNECTION (LATERAL STRANDS COILED IN SPLICE CLOSURE)	
	Green	15	COILED IN FIBER OPTIC INTERCONNECT CENTER	NO CONNECTION (LATERAL STRANDS COILED IN SPLICE CLOSURE)	
	Brown	16	COILED IN FIBER OPTIC INTERCONNECT CENTER	NO CONNECTION (LATERAL STRANDS COILED IN SPLICE CLOSURE)	
	Slate	17	COILED IN FIBER OPTIC INTERCONNECT CENTER	NO CONNECTION (LATERAL STRANDS COILED IN SPLICE CLOSURE)	
	White	18	COILED IN FIBER OPTIC INTERCONNECT CENTER	NO CONNECTION (LATERAL STRANDS COILED IN SPLICE CLOSURE)	
	Red	19	COILED IN FIBER OPTIC INTERCONNECT CENTER	NO CONNECTION (LATERAL STRANDS COILED IN SPLICE CLOSURE)	
	Black	20	COILED IN FIBER OPTIC INTERCONNECT CENTER	NO CONNECTION (LATERAL STRANDS COILED IN SPLICE CLOSURE)	
	Yellow	21	COILED IN FIBER OPTIC INTERCONNECT CENTER	NO CONNECTION (LATERAL STRANDS COILED IN SPLICE CLOSURE)	
	Violet	10	COILED IN FIBER OPTIC INTERCONNECT CENTER	NO CONNECTION (LATERAL STRANDS COILED IN SPLICE CLOSURE)	
	Rose	11	COILED IN FIBER OPTIC INTERCONNECT CENTER	NO CONNECTION (LATERAL STRANDS COILED IN SPLICE CLOSURE)	
	Aqua	12	COILED IN FIBER OPTIC INTERCONNECT CENTER	NO CONNECTION (LATERAL STRANDS COILED IN SPLICE CLOSURE)	

Kimley»Horn
© 2023 KIMLEY-HORN AND ASSOCIATES, INC.
4201 WHITEFIELD ROAD, SUITE 600
WARRENVILLE, IL 60555
PHONE: 630-487-6550
WWW.KIMLEY-HORN.COM

USER NAME =	DESIGNED -	REVISED -
	DRAWN -	REVISED -
PLOT SCALE =	CHECKED -	REVISED -
PLOT DATE =	DATE -	REVISED -

STATE OF ILLINOIS
DEPARTMENT OF TRANSPORTATION

FIBER OPTIC LATERAL CABLE SPLICE ASSIGNMENTS					
LCF-NO-002c					
SCALE:	SHEET	OF	SHEETS	STA.	TO STA.

F.A.P. RTE.	SECTION	COUNTY	TOTAL SHEETS	SHEET NO.
307	2020-263-SUR,SW&TS	DUPAGE	529	447
		CONTRACT NO. 62N33		
ILLINOIS		FED. AID PROJECT		

MODEL: Default
FILE: Kimley-Horn\Bentley.com\k-h-pw-d\1\Documents\01 Active Projects\MW-CUS-16895\100 - IL 64\Phase 1\12 Design\CAD\Plan Sheets\Communications\West Corridor\108121-ehf-comm-lateral-08.ktm.dgn

LATERAL CABLE FIBER ASSIGNMENTS				ORIGINATION	CAB-NO-006
LATERAL CABLE DESIGNATION			LCF-NO-002d	DESTINATION	CMV-NO-006B
BUFFER TUBE	FIBER	FIBER NO.	CABINET CONNECTIONS	DISTRIBUTION CABLE CONNECTIONS	
BLUE	Blue	1	1	PATCH PANEL "A" PORT 1 (JUMPERED TO LAYER II ETHERNET SWITCH)	DCF-NO-002 (WB), FIBER 7
	Orange	2	2	PATCH PANEL "A" PORT 2 (JUMPERED TO LAYER II ETHERNET SWITCH)	DCF-NO-002 (WB), FIBER 8
	Green	3	3	PATCH PANEL "A" PORT 3	NO CONNECTION (LATERAL STRANDS COILED IN SPLICE CLOSURE)
	Brown	4	4	PATCH PANEL "A" PORT 4	NO CONNECTION (LATERAL STRANDS COILED IN SPLICE CLOSURE)
	Slate	5	5	PATCH PANEL "A" PORT 5	NO CONNECTION (LATERAL STRANDS COILED IN SPLICE CLOSURE)
	White	6	6	PATCH PANEL "A" PORT 6	NO CONNECTION (LATERAL STRANDS COILED IN SPLICE CLOSURE)
	Red	7	7	PATCH PANEL "A" PORT 7 (JUMPERED TO LAYER II ETHERNET SWITCH)	DCF-NO-002 (EB), FIBER 7
	Black	8	8	PATCH PANEL "A" PORT 8 (JUMPERED TO LAYER II ETHERNET SWITCH)	DCF-NO-002 (EB), FIBER 8
	Yellow	9	9	PATCH PANEL "A" PORT 9	NO CONNECTION (LATERAL STRANDS COILED IN SPLICE CLOSURE)
	Violet	10	10	PATCH PANEL "A" PORT 10	NO CONNECTION (LATERAL STRANDS COILED IN SPLICE CLOSURE)
	Rose	11	11	PATCH PANEL "A" PORT 11	NO CONNECTION (LATERAL STRANDS COILED IN SPLICE CLOSURE)
	Aqua	12	12	PATCH PANEL "A" PORT 12	NO CONNECTION (LATERAL STRANDS COILED IN SPLICE CLOSURE)
ORANGE	Blue	1	13	COILED IN FIBER OPTIC INTERCONNECT CENTER	NO CONNECTION (LATERAL STRANDS COILED IN SPLICE CLOSURE)
	Orange	2	14	COILED IN FIBER OPTIC INTERCONNECT CENTER	NO CONNECTION (LATERAL STRANDS COILED IN SPLICE CLOSURE)
	Green	3	15	COILED IN FIBER OPTIC INTERCONNECT CENTER	NO CONNECTION (LATERAL STRANDS COILED IN SPLICE CLOSURE)
	Brown	4	16	COILED IN FIBER OPTIC INTERCONNECT CENTER	NO CONNECTION (LATERAL STRANDS COILED IN SPLICE CLOSURE)
	Slate	5	17	COILED IN FIBER OPTIC INTERCONNECT CENTER	NO CONNECTION (LATERAL STRANDS COILED IN SPLICE CLOSURE)
	White	6	18	COILED IN FIBER OPTIC INTERCONNECT CENTER	NO CONNECTION (LATERAL STRANDS COILED IN SPLICE CLOSURE)
	Red	7	19	COILED IN FIBER OPTIC INTERCONNECT CENTER	NO CONNECTION (LATERAL STRANDS COILED IN SPLICE CLOSURE)
	Black	8	20	COILED IN FIBER OPTIC INTERCONNECT CENTER	NO CONNECTION (LATERAL STRANDS COILED IN SPLICE CLOSURE)
	Yellow	9	21	COILED IN FIBER OPTIC INTERCONNECT CENTER	NO CONNECTION (LATERAL STRANDS COILED IN SPLICE CLOSURE)
	Violet	10	22	COILED IN FIBER OPTIC INTERCONNECT CENTER	NO CONNECTION (LATERAL STRANDS COILED IN SPLICE CLOSURE)
	Rose	11	23	COILED IN FIBER OPTIC INTERCONNECT CENTER	NO CONNECTION (LATERAL STRANDS COILED IN SPLICE CLOSURE)
	Aqua	12	24	COILED IN FIBER OPTIC INTERCONNECT CENTER	NO CONNECTION (LATERAL STRANDS COILED IN SPLICE CLOSURE)



© 2023 KIMLEY-HORN AND ASSOCIATES, INC.
4001 HWY 10 ROAD, SUITE 600
WARREN, IL 60555
PHONE: 815.447.4555
WWW.KIMLEY-HORN.COM

USER NAME	=
PLOT SCALE	=
PLOT DATE	=

DESIGNED	-
DRAWN	-
CHECKED	-
DATE	-

REVISED	-
REVISED	-
REVISED	-
REVISED	-

STATE OF ILLINOIS
DEPARTMENT OF TRANSPORTATION

FIBER OPTIC LATERAL CABLE SPLICE ASSIGNMENTS
LCF-NO-02d

SCALE:	SHEET	OF	SHEETS	STA.	TO	STA.
--------	-------	----	--------	------	----	------

F.A.P. RTE.	SECTION	COUNTY	TOTAL SHEETS	SHEET NO.
307	2020-263-SUR,SW&TS	DUPAGE	529	448
CONTRACT NO. 62N33				
		ILLINOIS	FED. AID PROJECT	

LATERAL CABLE FIBER ASSIGNMENTS				ORIGINATION	CAB-NO-006A
LATERAL CABLE DESIGNATION			LCF-NO-002e	DESTINATION	CMV-NO-006E
BUFFER TUBE	FIBER	FIBER NO.	CABINET CONNECTIONS	DISTRIBUTION CABLE CONNECTIONS	
BLUE	Blue	1	PATCH PANEL "A" PORT 1 (JUMPERED TO LAYER II ETHERNET SWITCH)	DCF-NO-002 (WB), FIBER 9	
	Orange	2	PATCH PANEL "A" PORT 2 (JUMPERED TO LAYER II ETHERNET SWITCH)	DCF-NO-002 (WB), FIBER 10	
	Green	3	PATCH PANEL "A" PORT 3	NO CONNECTION (LATERAL STRANDS COILED IN SPLICE CLOSURE)	
	Brown	4	PATCH PANEL "A" PORT 4	NO CONNECTION (LATERAL STRANDS COILED IN SPLICE CLOSURE)	
	Slate	5	PATCH PANEL "A" PORT 5	NO CONNECTION (LATERAL STRANDS COILED IN SPLICE CLOSURE)	
	White	6	PATCH PANEL "A" PORT 6	NO CONNECTION (LATERAL STRANDS COILED IN SPLICE CLOSURE)	
	Red	7	PATCH PANEL "A" PORT 7 (JUMPERED TO LAYER II ETHERNET SWITCH)	DCF-NO-002 (EB), FIBER 9	
	Black	8	PATCH PANEL "A" PORT 8 (JUMPERED TO LAYER II ETHERNET SWITCH)	DCF-NO-002 (EB), FIBER 10	
	Yellow	9	PATCH PANEL "A" PORT 9	NO CONNECTION (LATERAL STRANDS COILED IN SPLICE CLOSURE)	
	Violet	10	PATCH PANEL "A" PORT 10	NO CONNECTION (LATERAL STRANDS COILED IN SPLICE CLOSURE)	
	Rose	11	PATCH PANEL "A" PORT 11	NO CONNECTION (LATERAL STRANDS COILED IN SPLICE CLOSURE)	
	Aqua	12	PATCH PANEL "A" PORT 12	NO CONNECTION (LATERAL STRANDS COILED IN SPLICE CLOSURE)	
ORANGE	Blue	13	COILED IN FIBER OPTIC INTERCONNECT CENTER	NO CONNECTION (LATERAL STRANDS COILED IN SPLICE CLOSURE)	
	Orange	14	COILED IN FIBER OPTIC INTERCONNECT CENTER	NO CONNECTION (LATERAL STRANDS COILED IN SPLICE CLOSURE)	
	Green	15	COILED IN FIBER OPTIC INTERCONNECT CENTER	NO CONNECTION (LATERAL STRANDS COILED IN SPLICE CLOSURE)	
	Brown	16	COILED IN FIBER OPTIC INTERCONNECT CENTER	NO CONNECTION (LATERAL STRANDS COILED IN SPLICE CLOSURE)	
	Slate	17	COILED IN FIBER OPTIC INTERCONNECT CENTER	NO CONNECTION (LATERAL STRANDS COILED IN SPLICE CLOSURE)	
	White	18	COILED IN FIBER OPTIC INTERCONNECT CENTER	NO CONNECTION (LATERAL STRANDS COILED IN SPLICE CLOSURE)	
	Red	19	COILED IN FIBER OPTIC INTERCONNECT CENTER	NO CONNECTION (LATERAL STRANDS COILED IN SPLICE CLOSURE)	
	Black	20	COILED IN FIBER OPTIC INTERCONNECT CENTER	NO CONNECTION (LATERAL STRANDS COILED IN SPLICE CLOSURE)	
	Yellow	21	COILED IN FIBER OPTIC INTERCONNECT CENTER	NO CONNECTION (LATERAL STRANDS COILED IN SPLICE CLOSURE)	
	Violet	10	COILED IN FIBER OPTIC INTERCONNECT CENTER	NO CONNECTION (LATERAL STRANDS COILED IN SPLICE CLOSURE)	
	Rose	11	COILED IN FIBER OPTIC INTERCONNECT CENTER	NO CONNECTION (LATERAL STRANDS COILED IN SPLICE CLOSURE)	
	Aqua	12	COILED IN FIBER OPTIC INTERCONNECT CENTER	NO CONNECTION (LATERAL STRANDS COILED IN SPLICE CLOSURE)	

Kimley»Horn
© 2025 KIMLEY-HORN AND ASSOCIATES, INC.
4201 WINTERFIELD ROAD, SUITE 600
WARRENVILLE, IL 60555
PHONE: 630-487-6550
WWW.KIMLEY-HORN.COM

USER NAME =	DESIGNED -	REVISED -
	DRAWN -	REVISED -
PLOT SCALE =	CHECKED -	REVISED -
PLOT DATE =	DATE -	REVISED -

STATE OF ILLINOIS
DEPARTMENT OF TRANSPORTATION

FIBER OPTIC LATERAL CABLE SPLICE ASSIGNMENTS					
LCF-NO-002e					
SCALE:	SHEET	OF	SHEETS	STA.	TO STA.

F.A.P. RTE.	SECTION	COUNTY	TOTAL SHEETS	SHEET NO.
307	2020-263-SUR,SW&TS	DUPAGE	529	449
		CONTRACT NO. 62N33		
ILLINOIS		FED. AID PROJECT		

LATERAL CABLE FIBER ASSIGNMENTS				ORIGINATION	CAB-NO-007
LATERAL CABLE DESIGNATION			LCF-NO-002f	DESTINATION	CMV-NO-007B
BUFFER TUBE	FIBER	FIBER NO.	CABINET CONNECTIONS	DISTRIBUTION CABLE CONNECTIONS	
BLUE	Blue	1	PATCH PANEL "A" PORT 1 (JUMPERED TO LAYER II ETHERNET SWITCH)	DCF-NO-002 (WB), FIBER 11	
	Orange	2	PATCH PANEL "A" PORT 2 (JUMPERED TO LAYER II ETHERNET SWITCH)	DCF-NO-002 (WB), FIBER 12	
	Green	3	PATCH PANEL "A" PORT 3	NO CONNECTION (LATERAL STRANDS COILED IN SPLICE CLOSURE)	
	Brown	4	PATCH PANEL "A" PORT 4	NO CONNECTION (LATERAL STRANDS COILED IN SPLICE CLOSURE)	
	Slate	5	PATCH PANEL "A" PORT 5	NO CONNECTION (LATERAL STRANDS COILED IN SPLICE CLOSURE)	
	White	6	PATCH PANEL "A" PORT 6	NO CONNECTION (LATERAL STRANDS COILED IN SPLICE CLOSURE)	
	Red	7	PATCH PANEL "A" PORT 7 (JUMPERED TO LAYER II ETHERNET SWITCH)	DCF-NO-002 (EB), FIBER 11	
	Black	8	PATCH PANEL "A" PORT 8 (JUMPERED TO LAYER II ETHERNET SWITCH)	DCF-NO-002 (EB), FIBER 12	
	Yellow	9	PATCH PANEL "A" PORT 9	NO CONNECTION (LATERAL STRANDS COILED IN SPLICE CLOSURE)	
	Violet	10	PATCH PANEL "A" PORT 10	NO CONNECTION (LATERAL STRANDS COILED IN SPLICE CLOSURE)	
	Rose	11	PATCH PANEL "A" PORT 11	NO CONNECTION (LATERAL STRANDS COILED IN SPLICE CLOSURE)	
	Aqua	12	PATCH PANEL "A" PORT 12	NO CONNECTION (LATERAL STRANDS COILED IN SPLICE CLOSURE)	
ORANGE	Blue	13	COILED IN FIBER OPTIC INTERCONNECT CENTER	NO CONNECTION (LATERAL STRANDS COILED IN SPLICE CLOSURE)	
	Orange	14	COILED IN FIBER OPTIC INTERCONNECT CENTER	NO CONNECTION (LATERAL STRANDS COILED IN SPLICE CLOSURE)	
	Green	15	COILED IN FIBER OPTIC INTERCONNECT CENTER	NO CONNECTION (LATERAL STRANDS COILED IN SPLICE CLOSURE)	
	Brown	16	COILED IN FIBER OPTIC INTERCONNECT CENTER	NO CONNECTION (LATERAL STRANDS COILED IN SPLICE CLOSURE)	
	Slate	17	COILED IN FIBER OPTIC INTERCONNECT CENTER	NO CONNECTION (LATERAL STRANDS COILED IN SPLICE CLOSURE)	
	White	18	COILED IN FIBER OPTIC INTERCONNECT CENTER	NO CONNECTION (LATERAL STRANDS COILED IN SPLICE CLOSURE)	
	Red	19	COILED IN FIBER OPTIC INTERCONNECT CENTER	NO CONNECTION (LATERAL STRANDS COILED IN SPLICE CLOSURE)	
	Black	20	COILED IN FIBER OPTIC INTERCONNECT CENTER	NO CONNECTION (LATERAL STRANDS COILED IN SPLICE CLOSURE)	
	Yellow	21	COILED IN FIBER OPTIC INTERCONNECT CENTER	NO CONNECTION (LATERAL STRANDS COILED IN SPLICE CLOSURE)	
	Violet	10	COILED IN FIBER OPTIC INTERCONNECT CENTER	NO CONNECTION (LATERAL STRANDS COILED IN SPLICE CLOSURE)	
	Rose	11	COILED IN FIBER OPTIC INTERCONNECT CENTER	NO CONNECTION (LATERAL STRANDS COILED IN SPLICE CLOSURE)	
	Aqua	12	COILED IN FIBER OPTIC INTERCONNECT CENTER	NO CONNECTION (LATERAL STRANDS COILED IN SPLICE CLOSURE)	

 © 2022 KIMLEY-HORN AND ASSOCIATES, INC. 4001 WILHELM D. ROSS, SUITE 600 WARREN, IL 6 00655 PHONE: 634-877-0000 WWW.KIMLEY-HORN.COM	USER NAME =	DESIGNED -	REVISED -	STATE OF ILLINOIS DEPARTMENT OF TRANSPORTATION	FIBER OPTIC LATERAL CABLE SPLICE ASSIGNMENTS LCF-NO-002f					F.A.P. RTE.	SECTION	COUNTY	TOTAL SHEETS	SHEET NO.
	PLOT SCALE =	DRAWN -	REVISED -							307	2020-263-SUR,SW&TS	DUPAGE	529	450
	PLOT DATE =	CHECKED -	REVISED -		SCALE: SHEET OF SHEETS STA. TO STA.					CONTRACT NO. 62N33				
		DATE	REVISED -							ILLINOIS FED. AID PROJECT				

MODEL: Default
FILE: Kimley-Horn\Bentley.com\k-h-gp-d\1\Documents\01 Active Projects\MW-CUS-16895\100 - IL 64\Phase 1\12 Design\CAD\Plan Sheets\Communications\West Corridor\108121-eh-cmm-lateral-11.khm.dgn

LATERAL CABLE FIBER ASSIGNMENTS				ORIGINATION	CAB-NO-008
LATERAL CABLE DESIGNATION			LCF-NO-002g	DESTINATION	CMV-NO-008C
BUFFER TUBE	FIBER	FIBER NO.	CABINET CONNECTIONS	DISTRIBUTION CABLE CONNECTIONS	
BLUE	Blue	1	1	PATCH PANEL "A" PORT 1 (JUMPERED TO LAYER II ETHERNET SWITCH)	DCF-NO-002 (WB), FIBER 13
	Orange	2	2	PATCH PANEL "A" PORT 2 (JUMPERED TO LAYER II ETHERNET SWITCH)	DCF-NO-002 (WB), FIBER 14
	Green	3	3	PATCH PANEL "A" PORT 3	NO CONNECTION (LATERAL STRANDS COILED IN SPLICE CLOSURE)
	Brown	4	4	PATCH PANEL "A" PORT 4	NO CONNECTION (LATERAL STRANDS COILED IN SPLICE CLOSURE)
	Slate	5	5	PATCH PANEL "A" PORT 5	NO CONNECTION (LATERAL STRANDS COILED IN SPLICE CLOSURE)
	White	6	6	PATCH PANEL "A" PORT 6	NO CONNECTION (LATERAL STRANDS COILED IN SPLICE CLOSURE)
	Red	7	7	PATCH PANEL "A" PORT 7 (JUMPERED TO LAYER II ETHERNET SWITCH)	DCF-NO-002 (EB), FIBER 13
	Black	8	8	PATCH PANEL "A" PORT 8 (JUMPERED TO LAYER II ETHERNET SWITCH)	DCF-NO-002 (EB), FIBER 14
	Yellow	9	9	PATCH PANEL "A" PORT 9	NO CONNECTION (LATERAL STRANDS COILED IN SPLICE CLOSURE)
	Violet	10	10	PATCH PANEL "A" PORT 10	NO CONNECTION (LATERAL STRANDS COILED IN SPLICE CLOSURE)
	Rose	11	11	PATCH PANEL "A" PORT 11	NO CONNECTION (LATERAL STRANDS COILED IN SPLICE CLOSURE)
	Aqua	12	12	PATCH PANEL "A" PORT 12	NO CONNECTION (LATERAL STRANDS COILED IN SPLICE CLOSURE)
ORANGE	Blue	1	13	COILED IN FIBER OPTIC INTERCONNECT CENTER	NO CONNECTION (LATERAL STRANDS COILED IN SPLICE CLOSURE)
	Orange	2	14	COILED IN FIBER OPTIC INTERCONNECT CENTER	NO CONNECTION (LATERAL STRANDS COILED IN SPLICE CLOSURE)
	Green	3	15	COILED IN FIBER OPTIC INTERCONNECT CENTER	NO CONNECTION (LATERAL STRANDS COILED IN SPLICE CLOSURE)
	Brown	4	16	COILED IN FIBER OPTIC INTERCONNECT CENTER	NO CONNECTION (LATERAL STRANDS COILED IN SPLICE CLOSURE)
	Slate	5	17	COILED IN FIBER OPTIC INTERCONNECT CENTER	NO CONNECTION (LATERAL STRANDS COILED IN SPLICE CLOSURE)
	White	6	18	COILED IN FIBER OPTIC INTERCONNECT CENTER	NO CONNECTION (LATERAL STRANDS COILED IN SPLICE CLOSURE)
	Red	7	19	COILED IN FIBER OPTIC INTERCONNECT CENTER	NO CONNECTION (LATERAL STRANDS COILED IN SPLICE CLOSURE)
	Black	8	20	COILED IN FIBER OPTIC INTERCONNECT CENTER	NO CONNECTION (LATERAL STRANDS COILED IN SPLICE CLOSURE)
	Yellow	9	21	COILED IN FIBER OPTIC INTERCONNECT CENTER	NO CONNECTION (LATERAL STRANDS COILED IN SPLICE CLOSURE)
	Violet	10	22	COILED IN FIBER OPTIC INTERCONNECT CENTER	NO CONNECTION (LATERAL STRANDS COILED IN SPLICE CLOSURE)
	Rose	11	23	COILED IN FIBER OPTIC INTERCONNECT CENTER	NO CONNECTION (LATERAL STRANDS COILED IN SPLICE CLOSURE)
	Aqua	12	24	COILED IN FIBER OPTIC INTERCONNECT CENTER	NO CONNECTION (LATERAL STRANDS COILED IN SPLICE CLOSURE)



© 2023 KIMLEY-HORN AND ASSOCIATES, INC.
4001 KIMLEY-HORN ROAD, SUITE 600
WARREN, ILL. 60555
PHONE: 815.447.4555
WWW.KIMLEY-HORN.COM

USER NAME	=	
PLOT SCALE	=	
PLOT DATE	=	

DESIGNED	-	
DRAWN	-	
CHECKED	-	
DATE	-	

REVISED	-	
REVISED	-	
REVISED	-	
REVISED	-	

STATE OF ILLINOIS
DEPARTMENT OF TRANSPORTATION

FIBER OPTIC LATERAL CABLE SPLICE ASSIGNMENTS
LCF-NO-002g

SCALE:	SHEET	OF	SHEETS	STA.	TO	STA.
--------	-------	----	--------	------	----	------

F.A.P. RTE.	SECTION	COUNTY	TOTAL SHEETS	SHEET NO.
307	2020-263-SUR, SW&TS	DUPAGE	529	451
CONTRACT NO. 62N33				
		ILLINOIS	FED. AID PROJECT	

MODEL: Default
FILE: Kimley-Horn\Bentley.com\k-h-gp-d\1\Documents\01 Active Projects\MW-CUS-16895\100 - IL 64\Phase II\2 Design\CAD\Plan Sheets\Communications\West Corridor\108121-eh-cmm-lateral-12.kim.dgn

LATERAL CABLE FIBER ASSIGNMENTS				ORIGINATION	CAB-NO-008A
LATERAL CABLE DESIGNATION			LCF-NO-002h	DESTINATION	CMV-NO-008D
BUFFER TUBE	FIBER	FIBER NO.	CABINET CONNECTIONS	DISTRIBUTION CABLE CONNECTIONS	
BLUE	Blue	1	1	PATCH PANEL "A" PORT 1 (JUMPERED TO LAYER II ETHERNET SWITCH)	DCF-NO-002 (WB), FIBER 15
	Orange	2	2	PATCH PANEL "A" PORT 2 (JUMPERED TO LAYER II ETHERNET SWITCH)	DCF-NO-002 (WB), FIBER 16
	Green	3	3	PATCH PANEL "A" PORT 3	NO CONNECTION (LATERAL STRANDS COILED IN SPLICE CLOSURE)
	Brown	4	4	PATCH PANEL "A" PORT 4	NO CONNECTION (LATERAL STRANDS COILED IN SPLICE CLOSURE)
	Slate	5	5	PATCH PANEL "A" PORT 5	NO CONNECTION (LATERAL STRANDS COILED IN SPLICE CLOSURE)
	White	6	6	PATCH PANEL "A" PORT 6	NO CONNECTION (LATERAL STRANDS COILED IN SPLICE CLOSURE)
	Red	7	7	PATCH PANEL "A" PORT 7 (JUMPERED TO LAYER II ETHERNET SWITCH)	DCF-NO-002 (EB), FIBER 15
	Black	8	8	PATCH PANEL "A" PORT 8 (JUMPERED TO LAYER II ETHERNET SWITCH)	DCF-NO-002 (EB), FIBER 16
	Yellow	9	9	PATCH PANEL "A" PORT 9	NO CONNECTION (LATERAL STRANDS COILED IN SPLICE CLOSURE)
	Violet	10	10	PATCH PANEL "A" PORT 10	NO CONNECTION (LATERAL STRANDS COILED IN SPLICE CLOSURE)
	Rose	11	11	PATCH PANEL "A" PORT 11	NO CONNECTION (LATERAL STRANDS COILED IN SPLICE CLOSURE)
	Aqua	12	12	PATCH PANEL "A" PORT 12	NO CONNECTION (LATERAL STRANDS COILED IN SPLICE CLOSURE)
ORANGE	Blue	1	13	COILED IN FIBER OPTIC INTERCONNECT CENTER	NO CONNECTION (LATERAL STRANDS COILED IN SPLICE CLOSURE)
	Orange	2	14	COILED IN FIBER OPTIC INTERCONNECT CENTER	NO CONNECTION (LATERAL STRANDS COILED IN SPLICE CLOSURE)
	Green	3	15	COILED IN FIBER OPTIC INTERCONNECT CENTER	NO CONNECTION (LATERAL STRANDS COILED IN SPLICE CLOSURE)
	Brown	4	16	COILED IN FIBER OPTIC INTERCONNECT CENTER	NO CONNECTION (LATERAL STRANDS COILED IN SPLICE CLOSURE)
	Slate	5	17	COILED IN FIBER OPTIC INTERCONNECT CENTER	NO CONNECTION (LATERAL STRANDS COILED IN SPLICE CLOSURE)
	White	6	18	COILED IN FIBER OPTIC INTERCONNECT CENTER	NO CONNECTION (LATERAL STRANDS COILED IN SPLICE CLOSURE)
	Red	7	19	COILED IN FIBER OPTIC INTERCONNECT CENTER	NO CONNECTION (LATERAL STRANDS COILED IN SPLICE CLOSURE)
	Black	8	20	COILED IN FIBER OPTIC INTERCONNECT CENTER	NO CONNECTION (LATERAL STRANDS COILED IN SPLICE CLOSURE)
	Yellow	9	21	COILED IN FIBER OPTIC INTERCONNECT CENTER	NO CONNECTION (LATERAL STRANDS COILED IN SPLICE CLOSURE)
	Violet	10	22	COILED IN FIBER OPTIC INTERCONNECT CENTER	NO CONNECTION (LATERAL STRANDS COILED IN SPLICE CLOSURE)
	Rose	11	23	COILED IN FIBER OPTIC INTERCONNECT CENTER	NO CONNECTION (LATERAL STRANDS COILED IN SPLICE CLOSURE)
	Aqua	12	24	COILED IN FIBER OPTIC INTERCONNECT CENTER	NO CONNECTION (LATERAL STRANDS COILED IN SPLICE CLOSURE)



© 2023 KIMLEY-HORN AND ASSOCIATES, INC.
4001 KIMLEY-HORN ROAD, SUITE 600
WARREN, IL 6. 0585
PHONE: 815.447.4555
WWW.KIMLEY-HORN.COM

USER NAME	=	
PLOT SCALE	=	
PLOT DATE	=	

DESIGNED	-	
DRAWN	-	
CHECKED	-	
DATE	-	

REVISED	-	
REVISED	-	
REVISED	-	
REVISED	-	

STATE OF ILLINOIS
DEPARTMENT OF TRANSPORTATION

FIBER OPTIC LATERAL CABLE SPLICE ASSIGNMENTS
LCF-NO-002h

SCALE:	SHEET	OF	SHEETS	STA.	TO	STA.
--------	-------	----	--------	------	----	------

F.A.P. RTE.	SECTION	COUNTY	TOTAL SHEETS	SHEET NO.
307	2020-263-SUR,SW&TS	DUPAGE	529	452
CONTRACT NO. 62N33				
		ILLINOIS	FED. AID PROJECT	

LATERAL CABLE FIBER ASSIGNMENTS				ORIGINATION	CAB-NO-009
LATERAL CABLE DESIGNATION			LCF-NO-002I	DESTINATION	CMV-NO-009B
BUFFER TUBE	FIBER	FIBER NO.	CABINET CONNECTIONS	DISTRIBUTION CABLE CONNECTIONS	
BLUE	Blue	1	PATCH PANEL "A" PORT 1 (JUMPERED TO LAYER II ETHERNET SWITCH)	DCF-NO-002 (WB), FIBER 17	
	Orange	2	PATCH PANEL "A" PORT 2 (JUMPERED TO LAYER II ETHERNET SWITCH)	DCF-NO-002 (WB), FIBER 18	
	Green	3	PATCH PANEL "A" PORT 3	NO CONNECTION (LATERAL STRANDS COILED IN SPLICE CLOSURE)	
	Brown	4	PATCH PANEL "A" PORT 4	NO CONNECTION (LATERAL STRANDS COILED IN SPLICE CLOSURE)	
	Slate	5	PATCH PANEL "A" PORT 5	NO CONNECTION (LATERAL STRANDS COILED IN SPLICE CLOSURE)	
	White	6	PATCH PANEL "A" PORT 6	NO CONNECTION (LATERAL STRANDS COILED IN SPLICE CLOSURE)	
	Red	7	PATCH PANEL "A" PORT 7 (JUMPERED TO LAYER II ETHERNET SWITCH)	DCF-NO-002 (EB), FIBER 17	
	Black	8	PATCH PANEL "A" PORT 8 (JUMPERED TO LAYER II ETHERNET SWITCH)	DCF-NO-002 (EB), FIBER 18	
	Yellow	9	PATCH PANEL "A" PORT 9	NO CONNECTION (LATERAL STRANDS COILED IN SPLICE CLOSURE)	
	Violet	10	PATCH PANEL "A" PORT 10	NO CONNECTION (LATERAL STRANDS COILED IN SPLICE CLOSURE)	
	Rose	11	PATCH PANEL "A" PORT 11	NO CONNECTION (LATERAL STRANDS COILED IN SPLICE CLOSURE)	
	Aqua	12	PATCH PANEL "A" PORT 12	NO CONNECTION (LATERAL STRANDS COILED IN SPLICE CLOSURE)	
ORANGE	Blue	13	COILED IN FIBER OPTIC INTERCONNECT CENTER	NO CONNECTION (LATERAL STRANDS COILED IN SPLICE CLOSURE)	
	Orange	14	COILED IN FIBER OPTIC INTERCONNECT CENTER	NO CONNECTION (LATERAL STRANDS COILED IN SPLICE CLOSURE)	
	Green	15	COILED IN FIBER OPTIC INTERCONNECT CENTER	NO CONNECTION (LATERAL STRANDS COILED IN SPLICE CLOSURE)	
	Brown	16	COILED IN FIBER OPTIC INTERCONNECT CENTER	NO CONNECTION (LATERAL STRANDS COILED IN SPLICE CLOSURE)	
	Slate	17	COILED IN FIBER OPTIC INTERCONNECT CENTER	NO CONNECTION (LATERAL STRANDS COILED IN SPLICE CLOSURE)	
	White	18	COILED IN FIBER OPTIC INTERCONNECT CENTER	NO CONNECTION (LATERAL STRANDS COILED IN SPLICE CLOSURE)	
	Red	19	COILED IN FIBER OPTIC INTERCONNECT CENTER	NO CONNECTION (LATERAL STRANDS COILED IN SPLICE CLOSURE)	
	Black	20	COILED IN FIBER OPTIC INTERCONNECT CENTER	NO CONNECTION (LATERAL STRANDS COILED IN SPLICE CLOSURE)	
	Yellow	21	COILED IN FIBER OPTIC INTERCONNECT CENTER	NO CONNECTION (LATERAL STRANDS COILED IN SPLICE CLOSURE)	
	Violet	10	COILED IN FIBER OPTIC INTERCONNECT CENTER	NO CONNECTION (LATERAL STRANDS COILED IN SPLICE CLOSURE)	
	Rose	11	COILED IN FIBER OPTIC INTERCONNECT CENTER	NO CONNECTION (LATERAL STRANDS COILED IN SPLICE CLOSURE)	
	Aqua	12	COILED IN FIBER OPTIC INTERCONNECT CENTER	NO CONNECTION (LATERAL STRANDS COILED IN SPLICE CLOSURE)	

Kimley»Horn © 2022 KIMLEY-HORN AND ASSOCIATES, INC. 4001 WILMINGTON ROAD, SUITE 600 VANDERBILT, IL 61085 PHONE: 815-684-4000 WWW.KH-BY-HORN.COM	USER NAME =	DESIGNED -	REVISED -	STATE OF ILLINOIS DEPARTMENT OF TRANSPORTATION	FIBER OPTIC LATERAL CABLE SPLICE ASSIGNMENTS LCF-NO-002i					F.A.P. RTE.	SECTION	COUNTY	TOTAL SHEETS	SHEET NO.
	PLOT SCALE =	DRAWN -	REVISED -							307	2020-263-SUR, SW&TS	DUPAGE	529	453
	PLOT DATE =	CHECKED -	REVISED -		CONTRACT NO. 62N333									
		DATE -	REVISED -		SCALE:	SHEET	OF	SHEETS	STA.	TO STA.	ILLINOIS	FED. AID PROJECT		

MODEL: Default
FILE: Kimley-Horn\Bentley.com\k-h-gp-d\1\Documents\01 Active Projects\MW-CUS-160950\00 - IL 64\Phase 1\12 Design\CAD\Plan Sheets\Communications\West Corridor\0108121-eh-cmm-lateral-16.ktm.dgn

LATERAL CABLE FIBER ASSIGNMENTS				ORIGINATION	CAB-NO-011
LATERAL CABLE DESIGNATION			LCF-NO-002I	DESTINATION	CMV-NO-011B
BUFFER TUBE	FIBER	FIBER NO.	CABINET CONNECTIONS	DISTRIBUTION CABLE CONNECTIONS	
BLUE	Blue	1	1	PATCH PANEL "A" PORT 1 (JUMPERED TO LAYER II ETHERNET SWITCH)	DCF-NO-002 (WB), FIBER 37
	Orange	2	2	PATCH PANEL "A" PORT 2 (JUMPERED TO LAYER II ETHERNET SWITCH)	DCF-NO-002 (WB), FIBER 38
	Green	3	3	PATCH PANEL "A" PORT 3	NO CONNECTION (LATERAL STRANDS COILED IN SPLICE CLOSURE)
	Brown	4	4	PATCH PANEL "A" PORT 4	NO CONNECTION (LATERAL STRANDS COILED IN SPLICE CLOSURE)
	Slate	5	5	PATCH PANEL "A" PORT 5	NO CONNECTION (LATERAL STRANDS COILED IN SPLICE CLOSURE)
	White	6	6	PATCH PANEL "A" PORT 6	NO CONNECTION (LATERAL STRANDS COILED IN SPLICE CLOSURE)
	Red	7	7	PATCH PANEL "A" PORT 7 (JUMPERED TO LAYER II ETHERNET SWITCH)	DCF-NO-002 (EB), FIBER 37
	Black	8	8	PATCH PANEL "A" PORT 8 (JUMPERED TO LAYER II ETHERNET SWITCH)	DCF-NO-002 (EB), FIBER 38
	Yellow	9	9	PATCH PANEL "A" PORT 9	NO CONNECTION (LATERAL STRANDS COILED IN SPLICE CLOSURE)
	Violet	10	10	PATCH PANEL "A" PORT 10	NO CONNECTION (LATERAL STRANDS COILED IN SPLICE CLOSURE)
	Rose	11	11	PATCH PANEL "A" PORT 11	NO CONNECTION (LATERAL STRANDS COILED IN SPLICE CLOSURE)
	Aqua	12	12	PATCH PANEL "A" PORT 12	NO CONNECTION (LATERAL STRANDS COILED IN SPLICE CLOSURE)
ORANGE	Blue	1	13	COILED IN FIBER OPTIC INTERCONNECT CENTER	NO CONNECTION (LATERAL STRANDS COILED IN SPLICE CLOSURE)
	Orange	2	14	COILED IN FIBER OPTIC INTERCONNECT CENTER	NO CONNECTION (LATERAL STRANDS COILED IN SPLICE CLOSURE)
	Green	3	15	COILED IN FIBER OPTIC INTERCONNECT CENTER	NO CONNECTION (LATERAL STRANDS COILED IN SPLICE CLOSURE)
	Brown	4	16	COILED IN FIBER OPTIC INTERCONNECT CENTER	NO CONNECTION (LATERAL STRANDS COILED IN SPLICE CLOSURE)
	Slate	5	17	COILED IN FIBER OPTIC INTERCONNECT CENTER	NO CONNECTION (LATERAL STRANDS COILED IN SPLICE CLOSURE)
	White	6	18	COILED IN FIBER OPTIC INTERCONNECT CENTER	NO CONNECTION (LATERAL STRANDS COILED IN SPLICE CLOSURE)
	Red	7	19	COILED IN FIBER OPTIC INTERCONNECT CENTER	NO CONNECTION (LATERAL STRANDS COILED IN SPLICE CLOSURE)
	Black	8	20	COILED IN FIBER OPTIC INTERCONNECT CENTER	NO CONNECTION (LATERAL STRANDS COILED IN SPLICE CLOSURE)
	Yellow	9	21	COILED IN FIBER OPTIC INTERCONNECT CENTER	NO CONNECTION (LATERAL STRANDS COILED IN SPLICE CLOSURE)
	Violet	10	22	COILED IN FIBER OPTIC INTERCONNECT CENTER	NO CONNECTION (LATERAL STRANDS COILED IN SPLICE CLOSURE)
	Rose	11	23	COILED IN FIBER OPTIC INTERCONNECT CENTER	NO CONNECTION (LATERAL STRANDS COILED IN SPLICE CLOSURE)
	Aqua	12	24	COILED IN FIBER OPTIC INTERCONNECT CENTER	NO CONNECTION (LATERAL STRANDS COILED IN SPLICE CLOSURE)



© 2023 KIMLEY-HORN AND ASSOCIATES, INC.
4001 KIMLEY-HORN ROAD, SUITE 600
WARREN, ILL. 60555
PHONE: 815.447.4555
WWW.KIMLEY-HORN.COM

USER NAME =	DESIGNED -	REVISED -
	DRAWN -	REVISED -
PLOT SCALE =	CHECKED -	REVISED -
PLOT DATE =	DATE -	REVISED -

STATE OF ILLINOIS
DEPARTMENT OF TRANSPORTATION

FIBER OPTIC LATERAL CABLE SPLICE ASSIGNMENTS
LCF-NO-002I

SCALE: SHEET OF SHEETS STA. TO STA.

F.A.P. RTE.	SECTION	COUNTY	TOTAL SHEETS	SHEET NO.
307	2020-263-SUR,SW&TS	DUPAGE	529	456
CONTRACT NO. 62N33				
		ILLINOIS	FED. AID PROJECT	

LATERAL CABLE FIBER ASSIGNMENTS				ORIGINATION	CAB-NO-011A
LATERAL CABLE DESIGNATION			LCF-NO-002m	DESTINATION	CMV-NO-011C
BUFFER TUBE	FIBER	FIBER NO.	CABINET CONNECTIONS	DISTRIBUTION CABLE CONNECTIONS	
BLUE	Blue	1	PATCH PANEL "A" PORT 1 (JUMPERED TO LAYER II ETHERNET SWITCH)	DCF-NO-002 (WB), FIBER 23	
	Orange	2	PATCH PANEL "A" PORT 2 (JUMPERED TO LAYER II ETHERNET SWITCH)	DCF-NO-002 (WB), FIBER 24	
	Green	3	PATCH PANEL "A" PORT 3	NO CONNECTION (LATERAL STRANDS COILED IN SPLICE CLOSURE)	
	Brown	4	PATCH PANEL "A" PORT 4	NO CONNECTION (LATERAL STRANDS COILED IN SPLICE CLOSURE)	
	Slate	5	PATCH PANEL "A" PORT 5	NO CONNECTION (LATERAL STRANDS COILED IN SPLICE CLOSURE)	
	White	6	PATCH PANEL "A" PORT 6	NO CONNECTION (LATERAL STRANDS COILED IN SPLICE CLOSURE)	
	Red	7	PATCH PANEL "A" PORT 7 (JUMPERED TO LAYER II ETHERNET SWITCH)	DCF-NO-002 (EB), FIBER 23	
	Black	8	PATCH PANEL "A" PORT 8 (JUMPERED TO LAYER II ETHERNET SWITCH)	DCF-NO-002 (EB), FIBER 24	
	Yellow	9	PATCH PANEL "A" PORT 9	NO CONNECTION (LATERAL STRANDS COILED IN SPLICE CLOSURE)	
	Violet	10	PATCH PANEL "A" PORT 10	NO CONNECTION (LATERAL STRANDS COILED IN SPLICE CLOSURE)	
	Rose	11	PATCH PANEL "A" PORT 11	NO CONNECTION (LATERAL STRANDS COILED IN SPLICE CLOSURE)	
	Aqua	12	PATCH PANEL "A" PORT 12	NO CONNECTION (LATERAL STRANDS COILED IN SPLICE CLOSURE)	
ORANGE	Blue	13	COILED IN FIBER OPTIC INTERCONNECT CENTER	NO CONNECTION (LATERAL STRANDS COILED IN SPLICE CLOSURE)	
	Orange	14	COILED IN FIBER OPTIC INTERCONNECT CENTER	NO CONNECTION (LATERAL STRANDS COILED IN SPLICE CLOSURE)	
	Green	15	COILED IN FIBER OPTIC INTERCONNECT CENTER	NO CONNECTION (LATERAL STRANDS COILED IN SPLICE CLOSURE)	
	Brown	16	COILED IN FIBER OPTIC INTERCONNECT CENTER	NO CONNECTION (LATERAL STRANDS COILED IN SPLICE CLOSURE)	
	Slate	17	COILED IN FIBER OPTIC INTERCONNECT CENTER	NO CONNECTION (LATERAL STRANDS COILED IN SPLICE CLOSURE)	
	White	18	COILED IN FIBER OPTIC INTERCONNECT CENTER	NO CONNECTION (LATERAL STRANDS COILED IN SPLICE CLOSURE)	
	Red	19	COILED IN FIBER OPTIC INTERCONNECT CENTER	NO CONNECTION (LATERAL STRANDS COILED IN SPLICE CLOSURE)	
	Black	20	COILED IN FIBER OPTIC INTERCONNECT CENTER	NO CONNECTION (LATERAL STRANDS COILED IN SPLICE CLOSURE)	
	Yellow	21	COILED IN FIBER OPTIC INTERCONNECT CENTER	NO CONNECTION (LATERAL STRANDS COILED IN SPLICE CLOSURE)	
	Violet	22	COILED IN FIBER OPTIC INTERCONNECT CENTER	NO CONNECTION (LATERAL STRANDS COILED IN SPLICE CLOSURE)	
	Rose	23	COILED IN FIBER OPTIC INTERCONNECT CENTER	NO CONNECTION (LATERAL STRANDS COILED IN SPLICE CLOSURE)	
	Aqua	24	COILED IN FIBER OPTIC INTERCONNECT CENTER	NO CONNECTION (LATERAL STRANDS COILED IN SPLICE CLOSURE)	

Kimley»Horn
© 2025 KIMLEY-HORN AND ASSOCIATES, INC.
4201 WINTERFIELD ROAD, SUITE 600
WARRENVILLE, IL 60555
PHONE: 630-487-6550
WWW.KIMLEY-HORN.COM

USER NAME =	DESIGNED -	REVISED -
	DRAWN -	REVISED -
PLOT SCALE =	CHECKED -	REVISED -
PLOT DATE =	DATE -	REVISED -

STATE OF ILLINOIS
DEPARTMENT OF TRANSPORTATION

FIBER OPTIC LATERAL CABLE SPLICE ASSIGNMENTS				
LCF-NO-002m				
SCALE:	SHEET	OF	SHEETS	STA. TO STA.

F.A.P. RTE.	SECTION	COUNTY	TOTAL SHEETS	SHEET NO.
307	2020-263-SUR,SW&TS	DUPAGE	529	457
		CONTRACT NO. 62N33		
ILLINOIS		FED. AID PROJECT		

MODEL: Default
FILE: Kimley-Horn\Bentley.com\k-h-gp-d\1\Documents\01 Active Projects\MW-CUS-16895\100 - IL 64\Phase 1\12 Design\CAD\Plan Sheets\Communications\West Corridor\108121-eh-cmm-lateral-18.klm.dgn

LATERAL CABLE FIBER ASSIGNMENTS				ORIGINATION	CAB-NO-011B
LATERAL CABLE DESIGNATION			LCF-NO-002n	DESTINATION	CMV-NO-011F
BUFFER TUBE	FIBER	FIBER NO.	CABINET CONNECTIONS	DISTRIBUTION CABLE CONNECTIONS	
BLUE	Blue	1	1	PATCH PANEL "A" PORT 1 (JUMPERED TO LAYER II ETHERNET SWITCH)	DCF-NO-002 (WB), FIBER 25
	Orange	2	2	PATCH PANEL "A" PORT 2 (JUMPERED TO LAYER II ETHERNET SWITCH)	DCF-NO-002 (WB), FIBER 26
	Green	3	3	PATCH PANEL "A" PORT 3	NO CONNECTION (LATERAL STRANDS COILED IN SPLICE CLOSURE)
	Brown	4	4	PATCH PANEL "A" PORT 4	NO CONNECTION (LATERAL STRANDS COILED IN SPLICE CLOSURE)
	Slate	5	5	PATCH PANEL "A" PORT 5	NO CONNECTION (LATERAL STRANDS COILED IN SPLICE CLOSURE)
	White	6	6	PATCH PANEL "A" PORT 6	NO CONNECTION (LATERAL STRANDS COILED IN SPLICE CLOSURE)
	Red	7	7	PATCH PANEL "A" PORT 7 (JUMPERED TO LAYER II ETHERNET SWITCH)	DCF-NO-002 (EB), FIBER 25
	Black	8	8	PATCH PANEL "A" PORT 8 (JUMPERED TO LAYER II ETHERNET SWITCH)	DCF-NO-002 (EB), FIBER 26
	Yellow	9	9	PATCH PANEL "A" PORT 9	NO CONNECTION (LATERAL STRANDS COILED IN SPLICE CLOSURE)
	Violet	10	10	PATCH PANEL "A" PORT 10	NO CONNECTION (LATERAL STRANDS COILED IN SPLICE CLOSURE)
	Rose	11	11	PATCH PANEL "A" PORT 11	NO CONNECTION (LATERAL STRANDS COILED IN SPLICE CLOSURE)
	Aqua	12	12	PATCH PANEL "A" PORT 12	NO CONNECTION (LATERAL STRANDS COILED IN SPLICE CLOSURE)
ORANGE	Blue	1	13	COILED IN FIBER OPTIC INTERCONNECT CENTER	NO CONNECTION (LATERAL STRANDS COILED IN SPLICE CLOSURE)
	Orange	2	14	COILED IN FIBER OPTIC INTERCONNECT CENTER	NO CONNECTION (LATERAL STRANDS COILED IN SPLICE CLOSURE)
	Green	3	15	COILED IN FIBER OPTIC INTERCONNECT CENTER	NO CONNECTION (LATERAL STRANDS COILED IN SPLICE CLOSURE)
	Brown	4	16	COILED IN FIBER OPTIC INTERCONNECT CENTER	NO CONNECTION (LATERAL STRANDS COILED IN SPLICE CLOSURE)
	Slate	5	17	COILED IN FIBER OPTIC INTERCONNECT CENTER	NO CONNECTION (LATERAL STRANDS COILED IN SPLICE CLOSURE)
	White	6	18	COILED IN FIBER OPTIC INTERCONNECT CENTER	NO CONNECTION (LATERAL STRANDS COILED IN SPLICE CLOSURE)
	Red	7	19	COILED IN FIBER OPTIC INTERCONNECT CENTER	NO CONNECTION (LATERAL STRANDS COILED IN SPLICE CLOSURE)
	Black	8	20	COILED IN FIBER OPTIC INTERCONNECT CENTER	NO CONNECTION (LATERAL STRANDS COILED IN SPLICE CLOSURE)
	Yellow	9	21	COILED IN FIBER OPTIC INTERCONNECT CENTER	NO CONNECTION (LATERAL STRANDS COILED IN SPLICE CLOSURE)
	Violet	10	22	COILED IN FIBER OPTIC INTERCONNECT CENTER	NO CONNECTION (LATERAL STRANDS COILED IN SPLICE CLOSURE)
	Rose	11	23	COILED IN FIBER OPTIC INTERCONNECT CENTER	NO CONNECTION (LATERAL STRANDS COILED IN SPLICE CLOSURE)
	Aqua	12	24	COILED IN FIBER OPTIC INTERCONNECT CENTER	NO CONNECTION (LATERAL STRANDS COILED IN SPLICE CLOSURE)



© 2023 KIMLEY-HORN AND ASSOCIATES, INC.
4001 KIMLEY-HORN ROAD, SUITE 600
WARREN, ILL. 60555
PHONE: 815.447.4555
WWW.KIMLEY-HORN.COM

USER NAME =	DESIGNED -	REVISED -
	DRAWN -	REVISED -
PLOT SCALE =	CHECKED -	REVISED -
PLOT DATE =	DATE -	REVISED -

STATE OF ILLINOIS
DEPARTMENT OF TRANSPORTATION

FIBER OPTIC LATERAL CABLE SPLICE ASSIGNMENTS
LCF-NO-002n

SCALE: SHEET OF SHEETS STA. TO STA.

F.A.P. RTE.	SECTION	COUNTY	TOTAL SHEETS	SHEET NO.
307	2020-263-SUR, SW&TS	DUPAGE	529	458
CONTRACT NO. 62N33				
		ILLINOIS	FED. AID PROJECT	

LATERAL CABLE FIBER ASSIGNMENTS				ORIGINATION	CAB-NO-011C
LATERAL CABLE DESIGNATION			LCF-NO-002o	DESTINATION	CMV-NO-011G
BUFFER TUBE	FIBER	FIBER NO.	CABINET CONNECTIONS	DISTRIBUTION CABLE CONNECTIONS	
BLUE	Blue	1	PATCH PANEL "A" PORT 1 (JUMPERED TO LAYER II ETHERNET SWITCH)	DCF-NO-002 (WB), FIBER 27	
	Orange	2	PATCH PANEL "A" PORT 2 (JUMPERED TO LAYER II ETHERNET SWITCH)	DCF-NO-002 (WB), FIBER 28	
	Green	3	PATCH PANEL "A" PORT 3	NO CONNECTION (LATERAL STRANDS COILED IN SPLICE CLOSURE)	
	Brown	4	PATCH PANEL "A" PORT 4	NO CONNECTION (LATERAL STRANDS COILED IN SPLICE CLOSURE)	
	Slate	5	PATCH PANEL "A" PORT 5	NO CONNECTION (LATERAL STRANDS COILED IN SPLICE CLOSURE)	
	White	6	PATCH PANEL "A" PORT 6	NO CONNECTION (LATERAL STRANDS COILED IN SPLICE CLOSURE)	
	Red	7	PATCH PANEL "A" PORT 7 (JUMPERED TO LAYER II ETHERNET SWITCH)	DCF-NO-002 (EB), FIBER 27	
	Black	8	PATCH PANEL "A" PORT 8 (JUMPERED TO LAYER II ETHERNET SWITCH)	DCF-NO-002 (EB), FIBER 28	
	Yellow	9	PATCH PANEL "A" PORT 9	NO CONNECTION (LATERAL STRANDS COILED IN SPLICE CLOSURE)	
	Violet	10	PATCH PANEL "A" PORT 10	NO CONNECTION (LATERAL STRANDS COILED IN SPLICE CLOSURE)	
	Rose	11	PATCH PANEL "A" PORT 11	NO CONNECTION (LATERAL STRANDS COILED IN SPLICE CLOSURE)	
	Aqua	12	PATCH PANEL "A" PORT 12	NO CONNECTION (LATERAL STRANDS COILED IN SPLICE CLOSURE)	
ORANGE	Blue	1	COILED IN FIBER OPTIC INTERCONNECT CENTER	NO CONNECTION (LATERAL STRANDS COILED IN SPLICE CLOSURE)	
	Orange	2	COILED IN FIBER OPTIC INTERCONNECT CENTER	NO CONNECTION (LATERAL STRANDS COILED IN SPLICE CLOSURE)	
	Green	3	COILED IN FIBER OPTIC INTERCONNECT CENTER	NO CONNECTION (LATERAL STRANDS COILED IN SPLICE CLOSURE)	
	Brown	4	COILED IN FIBER OPTIC INTERCONNECT CENTER	NO CONNECTION (LATERAL STRANDS COILED IN SPLICE CLOSURE)	
	Slate	5	COILED IN FIBER OPTIC INTERCONNECT CENTER	NO CONNECTION (LATERAL STRANDS COILED IN SPLICE CLOSURE)	
	White	6	COILED IN FIBER OPTIC INTERCONNECT CENTER	NO CONNECTION (LATERAL STRANDS COILED IN SPLICE CLOSURE)	
	Red	7	COILED IN FIBER OPTIC INTERCONNECT CENTER	NO CONNECTION (LATERAL STRANDS COILED IN SPLICE CLOSURE)	
	Black	8	COILED IN FIBER OPTIC INTERCONNECT CENTER	NO CONNECTION (LATERAL STRANDS COILED IN SPLICE CLOSURE)	
	Yellow	9	COILED IN FIBER OPTIC INTERCONNECT CENTER	NO CONNECTION (LATERAL STRANDS COILED IN SPLICE CLOSURE)	
	Violet	10	COILED IN FIBER OPTIC INTERCONNECT CENTER	NO CONNECTION (LATERAL STRANDS COILED IN SPLICE CLOSURE)	
	Rose	11	COILED IN FIBER OPTIC INTERCONNECT CENTER	NO CONNECTION (LATERAL STRANDS COILED IN SPLICE CLOSURE)	
	Aqua	12	COILED IN FIBER OPTIC INTERCONNECT CENTER	NO CONNECTION (LATERAL STRANDS COILED IN SPLICE CLOSURE)	

Kimley»Horn
© 2023 KIMLEY-HORN AND ASSOCIATES, INC.
4201 WINFIELD ROAD, SUITE 803
WARRENVILLE, IL 60555
PHONE: 630-487-6550
WWW.KIMLEY-HORN.COM

USER NAME =	DESIGNED -	REVISED -
	DRAWN -	REVISED -
PLOT SCALE =	CHECKED -	REVISED -
PLOT DATE =	DATE -	REVISED -

STATE OF ILLINOIS
DEPARTMENT OF TRANSPORTATION

FIBER OPTIC LATERAL CABLE SPLICE ASSIGNMENTS				
LCF-NO-002a				
SCALE:	SHEET	OF	SHEETS	STA. TO STA.

F.A.P. RTE.	SECTION	COUNTY	TOTAL SHEETS	SHEET NO.
307	2020-263-SUR,SW&TS	DUPAGE	529	459
		CONTRACT NO. 62N33		
ILLINOIS		FED. AID PROJECT		

Model: Default
File: Kimley-Horn\Bentley.com\k-h-pw-d\Documents\01 Active Projects\MW-CUS-160950\00 - IL 64\Phase II\2 Design\CAD\Plan Sheets\Communications\West Corridor\0108121-eh-cmm-lateral-20.klm.dgn

LATERAL CABLE FIBER ASSIGNMENTS				ORIGINATION	CAB-NO-014
LATERAL CABLE DESIGNATION			LCF-NO-003g	DESTINATION	CMV-NO-014A
BUFFER TUBE	FIBER	FIBER NO.	CABINET CONNECTIONS	DISTRIBUTION CABLE CONNECTIONS	
BLUE	Blue	1	1	PATCH PANEL "A" PORT 1 (JUMPERED TO LAYER II ETHERNET SWITCH)	DCF-NO-003 (WB), FIBER 23
	Orange	2	2	PATCH PANEL "A" PORT 2 (JUMPERED TO LAYER II ETHERNET SWITCH)	DCF-NO-003 (WB), FIBER 24
	Green	3	3	PATCH PANEL "A" PORT 3	NO CONNECTION (LATERAL STRANDS COILED IN SPLICE CLOSURE)
	Brown	4	4	PATCH PANEL "A" PORT 4	NO CONNECTION (LATERAL STRANDS COILED IN SPLICE CLOSURE)
	Slate	5	5	PATCH PANEL "A" PORT 5	NO CONNECTION (LATERAL STRANDS COILED IN SPLICE CLOSURE)
	White	6	6	PATCH PANEL "A" PORT 6	NO CONNECTION (LATERAL STRANDS COILED IN SPLICE CLOSURE)
	Red	7	7	PATCH PANEL "A" PORT 7 (JUMPERED TO LAYER II ETHERNET SWITCH)	DCF-NO-003 (EB), FIBER 23
	Black	8	8	PATCH PANEL "A" PORT 8 (JUMPERED TO LAYER II ETHERNET SWITCH)	DCF-NO-003 (EB), FIBER 24
	Yellow	9	9	PATCH PANEL "A" PORT 9	NO CONNECTION (LATERAL STRANDS COILED IN SPLICE CLOSURE)
	Violet	10	10	PATCH PANEL "A" PORT 10	NO CONNECTION (LATERAL STRANDS COILED IN SPLICE CLOSURE)
	Rose	11	11	PATCH PANEL "A" PORT 11	NO CONNECTION (LATERAL STRANDS COILED IN SPLICE CLOSURE)
	Aqua	12	12	PATCH PANEL "A" PORT 12	NO CONNECTION (LATERAL STRANDS COILED IN SPLICE CLOSURE)
ORANGE	Blue	1	13	COILED IN FIBER OPTIC INTERCONNECT CENTER	NO CONNECTION (LATERAL STRANDS COILED IN SPLICE CLOSURE)
	Orange	2	14	COILED IN FIBER OPTIC INTERCONNECT CENTER	NO CONNECTION (LATERAL STRANDS COILED IN SPLICE CLOSURE)
	Green	3	15	COILED IN FIBER OPTIC INTERCONNECT CENTER	NO CONNECTION (LATERAL STRANDS COILED IN SPLICE CLOSURE)
	Brown	4	16	COILED IN FIBER OPTIC INTERCONNECT CENTER	NO CONNECTION (LATERAL STRANDS COILED IN SPLICE CLOSURE)
	Slate	5	17	COILED IN FIBER OPTIC INTERCONNECT CENTER	NO CONNECTION (LATERAL STRANDS COILED IN SPLICE CLOSURE)
	White	6	18	COILED IN FIBER OPTIC INTERCONNECT CENTER	NO CONNECTION (LATERAL STRANDS COILED IN SPLICE CLOSURE)
	Red	7	19	COILED IN FIBER OPTIC INTERCONNECT CENTER	NO CONNECTION (LATERAL STRANDS COILED IN SPLICE CLOSURE)
	Black	8	20	COILED IN FIBER OPTIC INTERCONNECT CENTER	NO CONNECTION (LATERAL STRANDS COILED IN SPLICE CLOSURE)
	Yellow	9	21	COILED IN FIBER OPTIC INTERCONNECT CENTER	NO CONNECTION (LATERAL STRANDS COILED IN SPLICE CLOSURE)
	Violet	10	22	COILED IN FIBER OPTIC INTERCONNECT CENTER	NO CONNECTION (LATERAL STRANDS COILED IN SPLICE CLOSURE)
	Rose	11	23	COILED IN FIBER OPTIC INTERCONNECT CENTER	NO CONNECTION (LATERAL STRANDS COILED IN SPLICE CLOSURE)
	Aqua	12	24	COILED IN FIBER OPTIC INTERCONNECT CENTER	NO CONNECTION (LATERAL STRANDS COILED IN SPLICE CLOSURE)



© 2023 KIMLEY-HORN AND ASSOCIATES, INC.
4001 KIMLEY-HORN ROAD, SUITE 600
WARREN, IL 6. 60555
PHONE: 815.447.4555
WWW.KIMLEY-HORN.COM

USER NAME	=	
PLOT SCALE	=	
PLOT DATE	=	

DESIGNED	-	
DRAWN	-	
CHECKED	-	
DATE	-	

REVISED	-	
REVISED	-	
REVISED	-	
REVISED	-	

STATE OF ILLINOIS
DEPARTMENT OF TRANSPORTATION

FIBER OPTIC LATERAL CABLE SPLICE ASSIGNMENTS
LCF-NO-003g

SCALE:	SHEET	OF	SHEETS	STA.	TO	STA.
--------	-------	----	--------	------	----	------

F.A.P. RTE.	SECTION	COUNTY	TOTAL SHEETS	SHEET NO.
307	2020-263-SUR,SW&TS	DUPAGE	529	460
CONTRACT NO. 62N33				
		ILLINOIS	FED. AID PROJECT	

LATERAL CABLE FIBER ASSIGNMENTS				ORIGINATION	CAB-NO-012B
LATERAL CABLE DESIGNATION			LCF-NO-003c	DESTINATION	CMV-NO-012E
BUFFER TUBE	FIBER	FIBER NO.	CABINET CONNECTIONS	DISTRIBUTION CABLE CONNECTIONS	
BLUE	Blue	1	PATCH PANEL "A" PORT 1 (JUMPERED TO LAYER II ETHERNET SWITCH)	DCF-NO-003 (WB), FIBER 15	
	Orange	2	PATCH PANEL "A" PORT 2 (JUMPERED TO LAYER II ETHERNET SWITCH)	DCF-NO-003 (WB), FIBER 16	
	Green	3	PATCH PANEL "A" PORT 3	NO CONNECTION (LATERAL STRANDS COILED IN SPLICE CLOSURE)	
	Brown	4	PATCH PANEL "A" PORT 4	NO CONNECTION (LATERAL STRANDS COILED IN SPLICE CLOSURE)	
	Slate	5	PATCH PANEL "A" PORT 5	NO CONNECTION (LATERAL STRANDS COILED IN SPLICE CLOSURE)	
	White	6	PATCH PANEL "A" PORT 6	NO CONNECTION (LATERAL STRANDS COILED IN SPLICE CLOSURE)	
	Red	7	PATCH PANEL "A" PORT 7 (JUMPERED TO LAYER II ETHERNET SWITCH)	DCF-NO-003 (EB), FIBER 15	
	Black	8	PATCH PANEL "A" PORT 8 (JUMPERED TO LAYER II ETHERNET SWITCH)	DCF-NO-003 (EB), FIBER 16	
	Yellow	9	PATCH PANEL "A" PORT 9	NO CONNECTION (LATERAL STRANDS COILED IN SPLICE CLOSURE)	
	Violet	10	PATCH PANEL "A" PORT 10	NO CONNECTION (LATERAL STRANDS COILED IN SPLICE CLOSURE)	
	Rose	11	PATCH PANEL "A" PORT 11	NO CONNECTION (LATERAL STRANDS COILED IN SPLICE CLOSURE)	
	Aqua	12	PATCH PANEL "A" PORT 12	NO CONNECTION (LATERAL STRANDS COILED IN SPLICE CLOSURE)	
ORANGE	Blue	13	COILED IN FIBER OPTIC INTERCONNECT CENTER	NO CONNECTION (LATERAL STRANDS COILED IN SPLICE CLOSURE)	
	Orange	14	COILED IN FIBER OPTIC INTERCONNECT CENTER	NO CONNECTION (LATERAL STRANDS COILED IN SPLICE CLOSURE)	
	Green	15	COILED IN FIBER OPTIC INTERCONNECT CENTER	NO CONNECTION (LATERAL STRANDS COILED IN SPLICE CLOSURE)	
	Brown	16	COILED IN FIBER OPTIC INTERCONNECT CENTER	NO CONNECTION (LATERAL STRANDS COILED IN SPLICE CLOSURE)	
	Slate	17	COILED IN FIBER OPTIC INTERCONNECT CENTER	NO CONNECTION (LATERAL STRANDS COILED IN SPLICE CLOSURE)	
	White	18	COILED IN FIBER OPTIC INTERCONNECT CENTER	NO CONNECTION (LATERAL STRANDS COILED IN SPLICE CLOSURE)	
	Red	19	COILED IN FIBER OPTIC INTERCONNECT CENTER	NO CONNECTION (LATERAL STRANDS COILED IN SPLICE CLOSURE)	
	Black	20	COILED IN FIBER OPTIC INTERCONNECT CENTER	NO CONNECTION (LATERAL STRANDS COILED IN SPLICE CLOSURE)	
	Yellow	21	COILED IN FIBER OPTIC INTERCONNECT CENTER	NO CONNECTION (LATERAL STRANDS COILED IN SPLICE CLOSURE)	
	Violet	10	COILED IN FIBER OPTIC INTERCONNECT CENTER	NO CONNECTION (LATERAL STRANDS COILED IN SPLICE CLOSURE)	
	Rose	11	COILED IN FIBER OPTIC INTERCONNECT CENTER	NO CONNECTION (LATERAL STRANDS COILED IN SPLICE CLOSURE)	
	Aqua	12	COILED IN FIBER OPTIC INTERCONNECT CENTER	NO CONNECTION (LATERAL STRANDS COILED IN SPLICE CLOSURE)	

Kimley»Horn
© 2025 KIMLEY-HORN AND ASSOCIATES, INC.
4201 WHITEFIELD ROAD, SUITE 600
WARRENVILLE, IL 60555
PHONE: 630-487-6550
WWW.KIMLEY-HORN.COM

USER NAME =	DESIGNED -	REVISED -
	DRAWN -	REVISED -
PLOT SCALE =	CHECKED -	REVISED -
PLOT DATE =	DATE -	REVISED -

STATE OF ILLINOIS
DEPARTMENT OF TRANSPORTATION

FIBER OPTIC LATERAL CABLE SPLICE ASSIGNMENTS					
LCF-NO-003c					
SCALE:	SHEET	OF	SHEETS	STA.	TO STA.

F.A.P. RTE.	SECTION	COUNTY	TOTAL SHEETS	SHEET NO.
307	2020-263-SUR,SW&TS	DUPAGE	529	463
		CONTRACT NO. 62N33		
ILLINOIS		FED. AID PROJECT		

MODEL: Default
FILE: Kimley-Horn\Bentley.com\k-h-pw-d\1\Documents\01 Active Projects\MW-CUS-16895\100 - IL 64\Phase 1\12 Design\CAD\Plan Sheets\Communications\West Corridor\108121-1-11-12-comm-lateral-24.kim.dgn

LATERAL CABLE FIBER ASSIGNMENTS				ORIGINATION	CAB-NO-013
LATERAL CABLE DESIGNATION			LCF-NO-003d	DESTINATION	CMV-NO-013A
BUFFER TUBE	FIBER	FIBER NO.	CABINET CONNECTIONS	DISTRIBUTION CABLE CONNECTIONS	
BLUE	Blue	1	1	PATCH PANEL "A" PORT 1 (JUMPERED TO LAYER II ETHERNET SWITCH)	DCF-NO-003 (WB), FIBER 17
	Orange	2	2	PATCH PANEL "A" PORT 2 (JUMPERED TO LAYER II ETHERNET SWITCH)	DCF-NO-003 (WB), FIBER 18
	Green	3	3	PATCH PANEL "A" PORT 3	NO CONNECTION (LATERAL STRANDS COILED IN SPLICE CLOSURE)
	Brown	4	4	PATCH PANEL "A" PORT 4	NO CONNECTION (LATERAL STRANDS COILED IN SPLICE CLOSURE)
	Slate	5	5	PATCH PANEL "A" PORT 5	NO CONNECTION (LATERAL STRANDS COILED IN SPLICE CLOSURE)
	White	6	6	PATCH PANEL "A" PORT 6	NO CONNECTION (LATERAL STRANDS COILED IN SPLICE CLOSURE)
	Red	7	7	PATCH PANEL "A" PORT 7 (JUMPERED TO LAYER II ETHERNET SWITCH)	DCF-NO-003 (EB), FIBER 17
	Black	8	8	PATCH PANEL "A" PORT 8 (JUMPERED TO LAYER II ETHERNET SWITCH)	DCF-NO-003 (EB), FIBER 18
	Yellow	9	9	PATCH PANEL "A" PORT 9	NO CONNECTION (LATERAL STRANDS COILED IN SPLICE CLOSURE)
	Violet	10	10	PATCH PANEL "A" PORT 10	NO CONNECTION (LATERAL STRANDS COILED IN SPLICE CLOSURE)
	Rose	11	11	PATCH PANEL "A" PORT 11	NO CONNECTION (LATERAL STRANDS COILED IN SPLICE CLOSURE)
	Aqua	12	12	PATCH PANEL "A" PORT 12	NO CONNECTION (LATERAL STRANDS COILED IN SPLICE CLOSURE)
ORANGE	Blue	1	13	COILED IN FIBER OPTIC INTERCONNECT CENTER	NO CONNECTION (LATERAL STRANDS COILED IN SPLICE CLOSURE)
	Orange	2	14	COILED IN FIBER OPTIC INTERCONNECT CENTER	NO CONNECTION (LATERAL STRANDS COILED IN SPLICE CLOSURE)
	Green	3	15	COILED IN FIBER OPTIC INTERCONNECT CENTER	NO CONNECTION (LATERAL STRANDS COILED IN SPLICE CLOSURE)
	Brown	4	16	COILED IN FIBER OPTIC INTERCONNECT CENTER	NO CONNECTION (LATERAL STRANDS COILED IN SPLICE CLOSURE)
	Slate	5	17	COILED IN FIBER OPTIC INTERCONNECT CENTER	NO CONNECTION (LATERAL STRANDS COILED IN SPLICE CLOSURE)
	White	6	18	COILED IN FIBER OPTIC INTERCONNECT CENTER	NO CONNECTION (LATERAL STRANDS COILED IN SPLICE CLOSURE)
	Red	7	19	COILED IN FIBER OPTIC INTERCONNECT CENTER	NO CONNECTION (LATERAL STRANDS COILED IN SPLICE CLOSURE)
	Black	8	20	COILED IN FIBER OPTIC INTERCONNECT CENTER	NO CONNECTION (LATERAL STRANDS COILED IN SPLICE CLOSURE)
	Yellow	9	21	COILED IN FIBER OPTIC INTERCONNECT CENTER	NO CONNECTION (LATERAL STRANDS COILED IN SPLICE CLOSURE)
	Violet	10	22	COILED IN FIBER OPTIC INTERCONNECT CENTER	NO CONNECTION (LATERAL STRANDS COILED IN SPLICE CLOSURE)
	Rose	11	23	COILED IN FIBER OPTIC INTERCONNECT CENTER	NO CONNECTION (LATERAL STRANDS COILED IN SPLICE CLOSURE)
	Aqua	12	24	COILED IN FIBER OPTIC INTERCONNECT CENTER	NO CONNECTION (LATERAL STRANDS COILED IN SPLICE CLOSURE)



© 2023 KIMLEY-HORN AND ASSOCIATES, INC.
4001 KIMLEY-HORN ROAD, SUITE 600
WARREN, ILL. 60555
PHONE: 815.447.4555
WWW.KIMLEY-HORN.COM

USER NAME	=
PLOT SCALE	=
PLOT DATE	=

DESIGNED	-
DRAWN	-
CHECKED	-
DATE	-

REVISED	-
REVISED	-
REVISED	-
REVISED	-

STATE OF ILLINOIS
DEPARTMENT OF TRANSPORTATION

FIBER OPTIC LATERAL CABLE SPLICE ASSIGNMENTS
LCF-NO-003d

SCALE:	SHEET	OF	SHEETS	STA.	TO STA.
--------	-------	----	--------	------	---------

F.A.P. RTE.	SECTION	COUNTY	TOTAL SHEETS	SHEET NO.
307	2020-263-SUR, SW&TS	DUPAGE	529	464
CONTRACT NO. 62N33				
		ILLINOIS	FED. AID PROJECT	

MODEL: Default
FILE: Kimley-Horn\Bentley.com\k-h-gp-d\1\Documents\01 Active Projects\MW-CUS-16895\100 - IL 64\Phase 1\12 Design\CAD\Plan Sheets\Communications\West Corridor\108121-eh-cmm-lateral-25.kim.dgn

LATERAL CABLE FIBER ASSIGNMENTS				ORIGINATION	CAB-NO-013A
LATERAL CABLE DESIGNATION			LCF-NO-003e	DESTINATION	CMV-NO-013D
BUFFER TUBE	FIBER	FIBER NO.	CABINET CONNECTIONS	DISTRIBUTION CABLE CONNECTIONS	
BLUE	Blue	1	1	PATCH PANEL "A" PORT 1 (JUMPERED TO LAYER II ETHERNET SWITCH)	DCF-NO-003 (WB), FIBER 19
	Orange	2	2	PATCH PANEL "A" PORT 2 (JUMPERED TO LAYER II ETHERNET SWITCH)	DCF-NO-003 (WB), FIBER 20
	Green	3	3	PATCH PANEL "A" PORT 3	NO CONNECTION (LATERAL STRANDS COILED IN SPLICE CLOSURE)
	Brown	4	4	PATCH PANEL "A" PORT 4	NO CONNECTION (LATERAL STRANDS COILED IN SPLICE CLOSURE)
	Slate	5	5	PATCH PANEL "A" PORT 5	NO CONNECTION (LATERAL STRANDS COILED IN SPLICE CLOSURE)
	White	6	6	PATCH PANEL "A" PORT 6	NO CONNECTION (LATERAL STRANDS COILED IN SPLICE CLOSURE)
	Red	7	7	PATCH PANEL "A" PORT 7 (JUMPERED TO LAYER II ETHERNET SWITCH)	DCF-NO-003 (EB), FIBER 19
	Black	8	8	PATCH PANEL "A" PORT 8 (JUMPERED TO LAYER II ETHERNET SWITCH)	DCF-NO-003 (EB), FIBER 20
	Yellow	9	9	PATCH PANEL "A" PORT 9	NO CONNECTION (LATERAL STRANDS COILED IN SPLICE CLOSURE)
	Violet	10	10	PATCH PANEL "A" PORT 10	NO CONNECTION (LATERAL STRANDS COILED IN SPLICE CLOSURE)
	Rose	11	11	PATCH PANEL "A" PORT 11	NO CONNECTION (LATERAL STRANDS COILED IN SPLICE CLOSURE)
	Aqua	12	12	PATCH PANEL "A" PORT 12	NO CONNECTION (LATERAL STRANDS COILED IN SPLICE CLOSURE)
ORANGE	Blue	1	13	COILED IN FIBER OPTIC INTERCONNECT CENTER	NO CONNECTION (LATERAL STRANDS COILED IN SPLICE CLOSURE)
	Orange	2	14	COILED IN FIBER OPTIC INTERCONNECT CENTER	NO CONNECTION (LATERAL STRANDS COILED IN SPLICE CLOSURE)
	Green	3	15	COILED IN FIBER OPTIC INTERCONNECT CENTER	NO CONNECTION (LATERAL STRANDS COILED IN SPLICE CLOSURE)
	Brown	4	16	COILED IN FIBER OPTIC INTERCONNECT CENTER	NO CONNECTION (LATERAL STRANDS COILED IN SPLICE CLOSURE)
	Slate	5	17	COILED IN FIBER OPTIC INTERCONNECT CENTER	NO CONNECTION (LATERAL STRANDS COILED IN SPLICE CLOSURE)
	White	6	18	COILED IN FIBER OPTIC INTERCONNECT CENTER	NO CONNECTION (LATERAL STRANDS COILED IN SPLICE CLOSURE)
	Red	7	19	COILED IN FIBER OPTIC INTERCONNECT CENTER	NO CONNECTION (LATERAL STRANDS COILED IN SPLICE CLOSURE)
	Black	8	20	COILED IN FIBER OPTIC INTERCONNECT CENTER	NO CONNECTION (LATERAL STRANDS COILED IN SPLICE CLOSURE)
	Yellow	9	21	COILED IN FIBER OPTIC INTERCONNECT CENTER	NO CONNECTION (LATERAL STRANDS COILED IN SPLICE CLOSURE)
	Violet	10	22	COILED IN FIBER OPTIC INTERCONNECT CENTER	NO CONNECTION (LATERAL STRANDS COILED IN SPLICE CLOSURE)
	Rose	11	23	COILED IN FIBER OPTIC INTERCONNECT CENTER	NO CONNECTION (LATERAL STRANDS COILED IN SPLICE CLOSURE)
	Aqua	12	24	COILED IN FIBER OPTIC INTERCONNECT CENTER	NO CONNECTION (LATERAL STRANDS COILED IN SPLICE CLOSURE)



© 2023 KIMLEY-HORN AND ASSOCIATES, INC.
4001 HWY 10 ROAD, SUITE 600
WARREN, IL 6. 60555
PHONE: 815.447.4555
WWW.KIMLEY-HORN.COM

USER NAME	=	
PLOT SCALE	=	
PLOT DATE	=	

DESIGNED	-	
DRAWN	-	
CHECKED	-	
DATE	-	

REVISED	-	
REVISED	-	
REVISED	-	
REVISED	-	

STATE OF ILLINOIS
DEPARTMENT OF TRANSPORTATION

FIBER OPTIC LATERAL CABLE SPLICE ASSIGNMENTS
LCF-NO-003e

SCALE:	SHEET	OF	SHEETS	STA.	TO	STA.
--------	-------	----	--------	------	----	------

F.A.P. RTE.	SECTION	COUNTY	TOTAL SHEETS	SHEET NO.
307	2020-263-SUR,SW&TS	DUPAGE	529	465
CONTRACT NO. 62N33				
		ILLINOIS	FED. AID PROJECT	

LATERAL CABLE FIBER ASSIGNMENTS				ORIGINATION	CAB-NO-014
LATERAL CABLE DESIGNATION			LCF-NO-003g	DESTINATION	CMV-NO-014A
BUFFER TUBE	FIBER	FIBER NO.	CABINET CONNECTIONS	DISTRIBUTION CABLE CONNECTIONS	
BLUE	Blue	1	PATCH PANEL "A" PORT 1 (JUMPERED TO LAYER II ETHERNET SWITCH)	DCF-NO-003 (WB), FIBER 23	
	Orange	2	PATCH PANEL "A" PORT 2 (JUMPERED TO LAYER II ETHERNET SWITCH)	DCF-NO-003 (WB), FIBER 24	
	Green	3	PATCH PANEL "A" PORT 3	NO CONNECTION (LATERAL STRANDS COILED IN SPLICE CLOSURE)	
	Brown	4	PATCH PANEL "A" PORT 4	NO CONNECTION (LATERAL STRANDS COILED IN SPLICE CLOSURE)	
	Slate	5	PATCH PANEL "A" PORT 5	NO CONNECTION (LATERAL STRANDS COILED IN SPLICE CLOSURE)	
	White	6	PATCH PANEL "A" PORT 6	NO CONNECTION (LATERAL STRANDS COILED IN SPLICE CLOSURE)	
	Red	7	PATCH PANEL "A" PORT 7 (JUMPERED TO LAYER II ETHERNET SWITCH)	DCF-NO-003 (EB), FIBER 23	
	Black	8	PATCH PANEL "A" PORT 8 (JUMPERED TO LAYER II ETHERNET SWITCH)	DCF-NO-003 (EB), FIBER 24	
	Yellow	9	PATCH PANEL "A" PORT 9	NO CONNECTION (LATERAL STRANDS COILED IN SPLICE CLOSURE)	
	Violet	10	PATCH PANEL "A" PORT 10	NO CONNECTION (LATERAL STRANDS COILED IN SPLICE CLOSURE)	
	Rose	11	PATCH PANEL "A" PORT 11	NO CONNECTION (LATERAL STRANDS COILED IN SPLICE CLOSURE)	
	Aqua	12	PATCH PANEL "A" PORT 12	NO CONNECTION (LATERAL STRANDS COILED IN SPLICE CLOSURE)	
ORANGE	Blue	13	COILED IN FIBER OPTIC INTERCONNECT CENTER	NO CONNECTION (LATERAL STRANDS COILED IN SPLICE CLOSURE)	
	Orange	14	COILED IN FIBER OPTIC INTERCONNECT CENTER	NO CONNECTION (LATERAL STRANDS COILED IN SPLICE CLOSURE)	
	Green	15	COILED IN FIBER OPTIC INTERCONNECT CENTER	NO CONNECTION (LATERAL STRANDS COILED IN SPLICE CLOSURE)	
	Brown	16	COILED IN FIBER OPTIC INTERCONNECT CENTER	NO CONNECTION (LATERAL STRANDS COILED IN SPLICE CLOSURE)	
	Slate	17	COILED IN FIBER OPTIC INTERCONNECT CENTER	NO CONNECTION (LATERAL STRANDS COILED IN SPLICE CLOSURE)	
	White	18	COILED IN FIBER OPTIC INTERCONNECT CENTER	NO CONNECTION (LATERAL STRANDS COILED IN SPLICE CLOSURE)	
	Red	19	COILED IN FIBER OPTIC INTERCONNECT CENTER	NO CONNECTION (LATERAL STRANDS COILED IN SPLICE CLOSURE)	
	Black	20	COILED IN FIBER OPTIC INTERCONNECT CENTER	NO CONNECTION (LATERAL STRANDS COILED IN SPLICE CLOSURE)	
	Yellow	21	COILED IN FIBER OPTIC INTERCONNECT CENTER	NO CONNECTION (LATERAL STRANDS COILED IN SPLICE CLOSURE)	
	Violet	10	COILED IN FIBER OPTIC INTERCONNECT CENTER	NO CONNECTION (LATERAL STRANDS COILED IN SPLICE CLOSURE)	
	Rose	11	COILED IN FIBER OPTIC INTERCONNECT CENTER	NO CONNECTION (LATERAL STRANDS COILED IN SPLICE CLOSURE)	
	Aqua	12	COILED IN FIBER OPTIC INTERCONNECT CENTER	NO CONNECTION (LATERAL STRANDS COILED IN SPLICE CLOSURE)	

Kimley»Horn
© 2023 KIMLEY-HORN AND ASSOCIATES, INC.
4201 WHITEFIELD ROAD, SUITE 600
WARRENVILLE, IL 60555
PHONE: 630-487-6550
WWW.KIMLEY-HORN.COM

USER NAME =	DESIGNED -	REVISED -
	DRAWN -	REVISED -
PLOT SCALE =	CHECKED -	REVISED -
PLOT DATE =	DATE -	REVISED -

STATE OF ILLINOIS
DEPARTMENT OF TRANSPORTATION

FIBER OPTIC LATERAL CABLE SPLICE ASSIGNMENTS					
LCF-NO-003g					
SCALE:	SHEET	OF	SHEETS	STA.	TO STA.

F.A.P. RTE.	SECTION	COUNTY	TOTAL SHEETS	SHEET NO.
307	2020-263-SUR,SW&TS	DUPAGE	529	467
		CONTRACT NO. 62N33		
ILLINOIS		FED. AID PROJECT		

Model: Default
File: Kimley-Horn\Bentley.com\k-h-gp-d\Documents\01 Active Projects\MW-CUS-160950\00 - IL 64\Phase II\2 Design\CAD\Plan Sheets\Communications\West Corridor\0108121-eh-conn-lateral-28.klm.dgn

LATERAL CABLE FIBER ASSIGNMENTS				ORIGINATION	CAB-NO-014A
LATERAL CABLE DESIGNATION			LCF-NO-003h	DESTINATION	CMV-NO-014E
BUFFER TUBE	FIBER	FIBER NO.	CABINET CONNECTIONS	DISTRIBUTION CABLE CONNECTIONS	
BLUE	Blue	1	1	PATCH PANEL "A" PORT 1 (JUMPERED TO LAYER II ETHERNET SWITCH)	DCF-NO-003 (WB), FIBER 25
	Orange	2	2	PATCH PANEL "A" PORT 2 (JUMPERED TO LAYER II ETHERNET SWITCH)	DCF-NO-003 (WB), FIBER 26
	Green	3	3	PATCH PANEL "A" PORT 3	NO CONNECTION (LATERAL STRANDS COILED IN SPLICE CLOSURE)
	Brown	4	4	PATCH PANEL "A" PORT 4	NO CONNECTION (LATERAL STRANDS COILED IN SPLICE CLOSURE)
	Slate	5	5	PATCH PANEL "A" PORT 5	NO CONNECTION (LATERAL STRANDS COILED IN SPLICE CLOSURE)
	White	6	6	PATCH PANEL "A" PORT 6	NO CONNECTION (LATERAL STRANDS COILED IN SPLICE CLOSURE)
	Red	7	7	PATCH PANEL "A" PORT 7 (JUMPERED TO LAYER II ETHERNET SWITCH)	DCF-NO-003 (EB), FIBER 25
	Black	8	8	PATCH PANEL "A" PORT 8 (JUMPERED TO LAYER II ETHERNET SWITCH)	DCF-NO-003 (EB), FIBER 26
	Yellow	9	9	PATCH PANEL "A" PORT 9	NO CONNECTION (LATERAL STRANDS COILED IN SPLICE CLOSURE)
	Violet	10	10	PATCH PANEL "A" PORT 10	NO CONNECTION (LATERAL STRANDS COILED IN SPLICE CLOSURE)
	Rose	11	11	PATCH PANEL "A" PORT 11	NO CONNECTION (LATERAL STRANDS COILED IN SPLICE CLOSURE)
	Aqua	12	12	PATCH PANEL "A" PORT 12	NO CONNECTION (LATERAL STRANDS COILED IN SPLICE CLOSURE)
ORANGE	Blue	1	13	COILED IN FIBER OPTIC INTERCONNECT CENTER	NO CONNECTION (LATERAL STRANDS COILED IN SPLICE CLOSURE)
	Orange	2	14	COILED IN FIBER OPTIC INTERCONNECT CENTER	NO CONNECTION (LATERAL STRANDS COILED IN SPLICE CLOSURE)
	Green	3	15	COILED IN FIBER OPTIC INTERCONNECT CENTER	NO CONNECTION (LATERAL STRANDS COILED IN SPLICE CLOSURE)
	Brown	4	16	COILED IN FIBER OPTIC INTERCONNECT CENTER	NO CONNECTION (LATERAL STRANDS COILED IN SPLICE CLOSURE)
	Slate	5	17	COILED IN FIBER OPTIC INTERCONNECT CENTER	NO CONNECTION (LATERAL STRANDS COILED IN SPLICE CLOSURE)
	White	6	18	COILED IN FIBER OPTIC INTERCONNECT CENTER	NO CONNECTION (LATERAL STRANDS COILED IN SPLICE CLOSURE)
	Red	7	19	COILED IN FIBER OPTIC INTERCONNECT CENTER	NO CONNECTION (LATERAL STRANDS COILED IN SPLICE CLOSURE)
	Black	8	20	COILED IN FIBER OPTIC INTERCONNECT CENTER	NO CONNECTION (LATERAL STRANDS COILED IN SPLICE CLOSURE)
	Yellow	9	21	COILED IN FIBER OPTIC INTERCONNECT CENTER	NO CONNECTION (LATERAL STRANDS COILED IN SPLICE CLOSURE)
	Violet	10	22	COILED IN FIBER OPTIC INTERCONNECT CENTER	NO CONNECTION (LATERAL STRANDS COILED IN SPLICE CLOSURE)
	Rose	11	23	COILED IN FIBER OPTIC INTERCONNECT CENTER	NO CONNECTION (LATERAL STRANDS COILED IN SPLICE CLOSURE)
	Aqua	12	24	COILED IN FIBER OPTIC INTERCONNECT CENTER	NO CONNECTION (LATERAL STRANDS COILED IN SPLICE CLOSURE)



© 2023 KIMLEY-HORN AND ASSOCIATES, INC.
4001 KIMLEY-HORN ROAD, SUITE 600
WARREN, ILL. 60555
PHONE: 815.447.4555
WWW.KIMLEY-HORN.COM

USER NAME	=	
PLOT SCALE	=	
PLOT DATE	=	

DESIGNED	-	
DRAWN	-	
CHECKED	-	
DATE	-	

REVISED	-	
REVISED	-	
REVISED	-	
REVISED	-	

STATE OF ILLINOIS
DEPARTMENT OF TRANSPORTATION

FIBER OPTIC LATERAL CABLE SPLICE ASSIGNMENTS
LCF-NO-003h

SCALE:	SHEET	OF	SHEETS	STA.	TO	STA.
--------	-------	----	--------	------	----	------

F.A.P. RTE.	SECTION	COUNTY	TOTAL SHEETS	SHEET NO.
307	2020-263-SUR, SW&TS	DUPAGE	529	468
CONTRACT NO. 62N33				
		ILLINOIS	FED. AID PROJECT	

LATERAL CABLE FIBER ASSIGNMENTS				ORIGINATION	CAB-NO-014B
LATERAL CABLE DESIGNATION			LCF-NO-003i	DESTINATION	CMV-NO-014G
BUFFER TUBE	FIBER	FIBER NO.	CABINET CONNECTIONS	DISTRIBUTION CABLE CONNECTIONS	
BLUE	Blue	1	PATCH PANEL "A" PORT 1 (JUMPERED TO LAYER II ETHERNET SWITCH)	DCF-NO-003 (WB), FIBER 27	
	Orange	2	PATCH PANEL "A" PORT 2 (JUMPERED TO LAYER II ETHERNET SWITCH)	DCF-NO-003 (WB), FIBER 28	
	Green	3	PATCH PANEL "A" PORT 3	NO CONNECTION (LATERAL STRANDS COILED IN SPLICE CLOSURE)	
	Brown	4	PATCH PANEL "A" PORT 4	NO CONNECTION (LATERAL STRANDS COILED IN SPLICE CLOSURE)	
	Slate	5	PATCH PANEL "A" PORT 5	NO CONNECTION (LATERAL STRANDS COILED IN SPLICE CLOSURE)	
	White	6	PATCH PANEL "A" PORT 6	NO CONNECTION (LATERAL STRANDS COILED IN SPLICE CLOSURE)	
	Red	7	PATCH PANEL "A" PORT 7 (JUMPERED TO LAYER II ETHERNET SWITCH)	DCF-NO-003 (EB), FIBER 27	
	Black	8	PATCH PANEL "A" PORT 8 (JUMPERED TO LAYER II ETHERNET SWITCH)	DCF-NO-003 (EB), FIBER 28	
	Yellow	9	PATCH PANEL "A" PORT 9	NO CONNECTION (LATERAL STRANDS COILED IN SPLICE CLOSURE)	
	Violet	10	PATCH PANEL "A" PORT 10	NO CONNECTION (LATERAL STRANDS COILED IN SPLICE CLOSURE)	
	Rose	11	PATCH PANEL "A" PORT 11	NO CONNECTION (LATERAL STRANDS COILED IN SPLICE CLOSURE)	
	Aqua	12	PATCH PANEL "A" PORT 12	NO CONNECTION (LATERAL STRANDS COILED IN SPLICE CLOSURE)	
ORANGE	Blue	13	COILED IN FIBER OPTIC INTERCONNECT CENTER	NO CONNECTION (LATERAL STRANDS COILED IN SPLICE CLOSURE)	
	Orange	14	COILED IN FIBER OPTIC INTERCONNECT CENTER	NO CONNECTION (LATERAL STRANDS COILED IN SPLICE CLOSURE)	
	Green	15	COILED IN FIBER OPTIC INTERCONNECT CENTER	NO CONNECTION (LATERAL STRANDS COILED IN SPLICE CLOSURE)	
	Brown	16	COILED IN FIBER OPTIC INTERCONNECT CENTER	NO CONNECTION (LATERAL STRANDS COILED IN SPLICE CLOSURE)	
	Slate	17	COILED IN FIBER OPTIC INTERCONNECT CENTER	NO CONNECTION (LATERAL STRANDS COILED IN SPLICE CLOSURE)	
	White	18	COILED IN FIBER OPTIC INTERCONNECT CENTER	NO CONNECTION (LATERAL STRANDS COILED IN SPLICE CLOSURE)	
	Red	19	COILED IN FIBER OPTIC INTERCONNECT CENTER	NO CONNECTION (LATERAL STRANDS COILED IN SPLICE CLOSURE)	
	Black	20	COILED IN FIBER OPTIC INTERCONNECT CENTER	NO CONNECTION (LATERAL STRANDS COILED IN SPLICE CLOSURE)	
	Yellow	21	COILED IN FIBER OPTIC INTERCONNECT CENTER	NO CONNECTION (LATERAL STRANDS COILED IN SPLICE CLOSURE)	
	Violet	10	COILED IN FIBER OPTIC INTERCONNECT CENTER	NO CONNECTION (LATERAL STRANDS COILED IN SPLICE CLOSURE)	
	Rose	11	COILED IN FIBER OPTIC INTERCONNECT CENTER	NO CONNECTION (LATERAL STRANDS COILED IN SPLICE CLOSURE)	
	Aqua	12	COILED IN FIBER OPTIC INTERCONNECT CENTER	NO CONNECTION (LATERAL STRANDS COILED IN SPLICE CLOSURE)	

Kimley»Horn
© 2025 KIMLEY-HORN AND ASSOCIATES, INC.
4201 WHITEFIELD ROAD, SUITE 600
WARRENVILLE, IL 60555
PHONE: 630-487-6550
WWW.KIMLEY-HORN.COM

USER NAME =	DESIGNED -	REVISED -
	DRAWN -	REVISED -
PLOT SCALE =	CHECKED -	REVISED -
PLOT DATE =	DATE -	REVISED -

STATE OF ILLINOIS
DEPARTMENT OF TRANSPORTATION

FIBER OPTIC LATERAL CABLE SPLICE ASSIGNMENTS					
LCF-NO-003i					
SCALE:	SHEET	OF	SHEETS	STA.	TO STA.

F.A.P. RTE.	SECTION	COUNTY	TOTAL SHEETS	SHEET NO.
307	2020-263-SUR,SW&TS	DUPAGE	529	469
		CONTRACT NO. 62N33		
ILLINOIS		FED. AID PROJECT		

Model: Default
File: Kimley-Horn-Bentley.com\k-h-pw-d\Documents\01 Active Projects\MW-CUS-160950\00 - IL 64\Phase II\2 Design\CAD\Plan Sheets\Communications\West Corridor\0108121-eh-conn-lateral-30.klm.dgn

LATERAL CABLE FIBER ASSIGNMENTS				ORIGINATION	CAB-NO-014C
LATERAL CABLE DESIGNATION			LCF-NO-003j	DESTINATION	CMV-NO-014I
BUFFER TUBE	FIBER	FIBER NO.	CABINET CONNECTIONS	DISTRIBUTION CABLE CONNECTIONS	
BLUE	Blue	1	1	PATCH PANEL "A" PORT 1 (JUMPERED TO LAYER II ETHERNET SWITCH)	DCF-NO-003 (WB), FIBER 39
	Orange	2	2	PATCH PANEL "A" PORT 2 (JUMPERED TO LAYER II ETHERNET SWITCH)	DCF-NO-003 (WB), FIBER 40
	Green	3	3	PATCH PANEL "A" PORT 3	NO CONNECTION (LATERAL STRANDS COILED IN SPLICE CLOSURE)
	Brown	4	4	PATCH PANEL "A" PORT 4	NO CONNECTION (LATERAL STRANDS COILED IN SPLICE CLOSURE)
	Slate	5	5	PATCH PANEL "A" PORT 5	NO CONNECTION (LATERAL STRANDS COILED IN SPLICE CLOSURE)
	White	6	6	PATCH PANEL "A" PORT 6	NO CONNECTION (LATERAL STRANDS COILED IN SPLICE CLOSURE)
	Red	7	7	PATCH PANEL "A" PORT 7 (JUMPERED TO LAYER II ETHERNET SWITCH)	DCF-NO-003 (EB), FIBER 39
	Black	8	8	PATCH PANEL "A" PORT 8 (JUMPERED TO LAYER II ETHERNET SWITCH)	DCF-NO-003 (EB), FIBER 40
	Yellow	9	9	PATCH PANEL "A" PORT 9	NO CONNECTION (LATERAL STRANDS COILED IN SPLICE CLOSURE)
	Violet	10	10	PATCH PANEL "A" PORT 10	NO CONNECTION (LATERAL STRANDS COILED IN SPLICE CLOSURE)
	Rose	11	11	PATCH PANEL "A" PORT 11	NO CONNECTION (LATERAL STRANDS COILED IN SPLICE CLOSURE)
	Aqua	12	12	PATCH PANEL "A" PORT 12	NO CONNECTION (LATERAL STRANDS COILED IN SPLICE CLOSURE)
ORANGE	Blue	1	13	COILED IN FIBER OPTIC INTERCONNECT CENTER	NO CONNECTION (LATERAL STRANDS COILED IN SPLICE CLOSURE)
	Orange	2	14	COILED IN FIBER OPTIC INTERCONNECT CENTER	NO CONNECTION (LATERAL STRANDS COILED IN SPLICE CLOSURE)
	Green	3	15	COILED IN FIBER OPTIC INTERCONNECT CENTER	NO CONNECTION (LATERAL STRANDS COILED IN SPLICE CLOSURE)
	Brown	4	16	COILED IN FIBER OPTIC INTERCONNECT CENTER	NO CONNECTION (LATERAL STRANDS COILED IN SPLICE CLOSURE)
	Slate	5	17	COILED IN FIBER OPTIC INTERCONNECT CENTER	NO CONNECTION (LATERAL STRANDS COILED IN SPLICE CLOSURE)
	White	6	18	COILED IN FIBER OPTIC INTERCONNECT CENTER	NO CONNECTION (LATERAL STRANDS COILED IN SPLICE CLOSURE)
	Red	7	19	COILED IN FIBER OPTIC INTERCONNECT CENTER	NO CONNECTION (LATERAL STRANDS COILED IN SPLICE CLOSURE)
	Black	8	20	COILED IN FIBER OPTIC INTERCONNECT CENTER	NO CONNECTION (LATERAL STRANDS COILED IN SPLICE CLOSURE)
	Yellow	9	21	COILED IN FIBER OPTIC INTERCONNECT CENTER	NO CONNECTION (LATERAL STRANDS COILED IN SPLICE CLOSURE)
	Violet	10	22	COILED IN FIBER OPTIC INTERCONNECT CENTER	NO CONNECTION (LATERAL STRANDS COILED IN SPLICE CLOSURE)
	Rose	11	23	COILED IN FIBER OPTIC INTERCONNECT CENTER	NO CONNECTION (LATERAL STRANDS COILED IN SPLICE CLOSURE)
	Aqua	12	24	COILED IN FIBER OPTIC INTERCONNECT CENTER	NO CONNECTION (LATERAL STRANDS COILED IN SPLICE CLOSURE)



© 2023 KIMLEY-HORN AND ASSOCIATES, INC.
4001 HWY 10 ROAD, SUITE 600
WARREN, IL 6. 0505
PHONE: 815.477.4555
WWW.KIMLEY-HORN.COM

USER NAME =	DESIGNED -	REVISED -
	DRAWN -	REVISED -
PLOT SCALE =	CHECKED -	REVISED -
PLOT DATE =	DATE -	REVISED -

STATE OF ILLINOIS
DEPARTMENT OF TRANSPORTATION

FIBER OPTIC LATERAL CABLE SPLICE ASSIGNMENTS
LCF-NO-003j

SCALE: SHEET OF SHEETS STA. TO STA.

F.A.P. RTE.	SECTION	COUNTY	TOTAL SHEETS	SHEET NO.
307	2020-263-SUR,SW&TS	DUPAGE	529	470
CONTRACT NO. 62N33				
		ILLINOIS	FED. AID PROJECT	

Model: Default
File: Kimley-Horn\Bentley.com\k-h-pw-d\Documents\01 Active Projects\MW-CUS-16895\100 - IL 64\Phase II\2 Design\CAD\Plan Sheets\Communications\West Corridor\108121-eh-cmm-lateral-31.khm.dgn

LATERAL CABLE FIBER ASSIGNMENTS				ORIGINATION	CAB-NO-015
LATERAL CABLE DESIGNATION			LCF-NO-003k	DESTINATION	CMV-NO-015
BUFFER TUBE	FIBER	FIBER NO.	CABINET CONNECTIONS	DISTRIBUTION CABLE CONNECTIONS	
BLUE	Blue	1	1	PATCH PANEL "A" PORT 1 (JUMPERED TO LAYER II ETHERNET SWITCH)	DCF-NO-003 (WB), FIBER 29
	Orange	2	2	PATCH PANEL "A" PORT 2 (JUMPERED TO LAYER II ETHERNET SWITCH)	DCF-NO-003 (WB), FIBER 30
	Green	3	3	PATCH PANEL "A" PORT 3	NO CONNECTION (LATERAL STRANDS COILED IN SPLICE CLOSURE)
	Brown	4	4	PATCH PANEL "A" PORT 4	NO CONNECTION (LATERAL STRANDS COILED IN SPLICE CLOSURE)
	Slate	5	5	PATCH PANEL "A" PORT 5	NO CONNECTION (LATERAL STRANDS COILED IN SPLICE CLOSURE)
	White	6	6	PATCH PANEL "A" PORT 6	NO CONNECTION (LATERAL STRANDS COILED IN SPLICE CLOSURE)
	Red	7	7	PATCH PANEL "A" PORT 7 (JUMPERED TO LAYER II ETHERNET SWITCH)	DCF-NO-003 (EB), FIBER 29
	Black	8	8	PATCH PANEL "A" PORT 8 (JUMPERED TO LAYER II ETHERNET SWITCH)	DCF-NO-003 (EB), FIBER 30
	Yellow	9	9	PATCH PANEL "A" PORT 9	NO CONNECTION (LATERAL STRANDS COILED IN SPLICE CLOSURE)
	Violet	10	10	PATCH PANEL "A" PORT 10	NO CONNECTION (LATERAL STRANDS COILED IN SPLICE CLOSURE)
	Rose	11	11	PATCH PANEL "A" PORT 11	NO CONNECTION (LATERAL STRANDS COILED IN SPLICE CLOSURE)
	Aqua	12	12	PATCH PANEL "A" PORT 12	NO CONNECTION (LATERAL STRANDS COILED IN SPLICE CLOSURE)
ORANGE	Blue	1	13	COILED IN FIBER OPTIC INTERCONNECT CENTER	NO CONNECTION (LATERAL STRANDS COILED IN SPLICE CLOSURE)
	Orange	2	14	COILED IN FIBER OPTIC INTERCONNECT CENTER	NO CONNECTION (LATERAL STRANDS COILED IN SPLICE CLOSURE)
	Green	3	15	COILED IN FIBER OPTIC INTERCONNECT CENTER	NO CONNECTION (LATERAL STRANDS COILED IN SPLICE CLOSURE)
	Brown	4	16	COILED IN FIBER OPTIC INTERCONNECT CENTER	NO CONNECTION (LATERAL STRANDS COILED IN SPLICE CLOSURE)
	Slate	5	17	COILED IN FIBER OPTIC INTERCONNECT CENTER	NO CONNECTION (LATERAL STRANDS COILED IN SPLICE CLOSURE)
	White	6	18	COILED IN FIBER OPTIC INTERCONNECT CENTER	NO CONNECTION (LATERAL STRANDS COILED IN SPLICE CLOSURE)
	Red	7	19	COILED IN FIBER OPTIC INTERCONNECT CENTER	NO CONNECTION (LATERAL STRANDS COILED IN SPLICE CLOSURE)
	Black	8	20	COILED IN FIBER OPTIC INTERCONNECT CENTER	NO CONNECTION (LATERAL STRANDS COILED IN SPLICE CLOSURE)
	Yellow	9	21	COILED IN FIBER OPTIC INTERCONNECT CENTER	NO CONNECTION (LATERAL STRANDS COILED IN SPLICE CLOSURE)
	Violet	10	22	COILED IN FIBER OPTIC INTERCONNECT CENTER	NO CONNECTION (LATERAL STRANDS COILED IN SPLICE CLOSURE)
	Rose	11	23	COILED IN FIBER OPTIC INTERCONNECT CENTER	NO CONNECTION (LATERAL STRANDS COILED IN SPLICE CLOSURE)
	Aqua	12	24	COILED IN FIBER OPTIC INTERCONNECT CENTER	NO CONNECTION (LATERAL STRANDS COILED IN SPLICE CLOSURE)



© 2023 KIMLEY-HORN AND ASSOCIATES, INC.
4001 HWY 10 ROAD, SUITE 600
WARREN, IL 6. 0585
PHONE: 815.477.4555
WWW.KIMLEY-HORN.COM

USER NAME	=	
PLOT SCALE	=	
PLOT DATE	=	

DESIGNED	-	
DRAWN	-	
CHECKED	-	
DATE	-	

REVISED	-	
REVISED	-	
REVISED	-	
REVISED	-	

STATE OF ILLINOIS
DEPARTMENT OF TRANSPORTATION

FIBER OPTIC LATERAL CABLE SPLICE ASSIGNMENTS
LCF-NO-003k

SCALE:	SHEET	OF	SHEETS	STA.	TO	STA.
--------	-------	----	--------	------	----	------

F.A.P. RTE.	SECTION	COUNTY	TOTAL SHEETS	SHEET NO.
307	2020-263-SUR,SW&TS	DUPAGE	529	471
CONTRACT NO. 62N33				
		ILLINOIS	FED. AID PROJECT	

MODEL: Default
FILE: Kimley-Horn\Bentley.com\k-h-gp-d\1\Documents\01 Active Projects\MW-CUS-168959\100 - IL 64\Phase II\2 Design\CAD\Plan Sheets\Communications\West Corridor\0108121-eh-cmm-lateral-33.klm.dgn

LATERAL CABLE FIBER ASSIGNMENTS				ORIGINATION	CAB-NO-015B
LATERAL CABLE DESIGNATION			LCF-NO-003m	DESTINATION	CMV-NO-015E
BUFFER TUBE	FIBER	FIBER NO.	CABINET CONNECTIONS	DISTRIBUTION CABLE CONNECTIONS	
BLUE	Blue	1	1	PATCH PANEL "A" PORT 1 (JUMPERED TO LAYER I II ETHERNET SWITCH)	DCF-NO-003 (WB), FIBER 31
	Orange	2	2	PATCH PANEL "A" PORT 2 (JUMPERED TO LAYER III ETHERNET SWITCH)	DCF-NO-003 (WB), FIBER 32
	Green	3	3	PATCH PANEL "A" PORT 3	NO CONNECTION (LATERAL STRANDS COILED IN SPLICE CLOSURE)
	Brown	4	4	PATCH PANEL "A" PORT 4	NO CONNECTION (LATERAL STRANDS COILED IN SPLICE CLOSURE)
	Slate	5	5	PATCH PANEL "A" PORT 5	NO CONNECTION (LATERAL STRANDS COILED IN SPLICE CLOSURE)
	White	6	6	PATCH PANEL "A" PORT 6	NO CONNECTION (LATERAL STRANDS COILED IN SPLICE CLOSURE)
	Red	7	7	PATCH PANEL "A" PORT 7 (JUMPERED TO LAYER III ETHERNET SWITCH)	DCF-NO-003 (EB), FIBER 31
	Black	8	8	PATCH PANEL "A" PORT 8 (JUMPERED TO LAYER III ETHERNET SWITCH)	DCF-NO-003 (EB), FIBER 32
	Yellow	9	9	PATCH PANEL "A" PORT 9	NO CONNECTION (LATERAL STRANDS COILED IN SPLICE CLOSURE)
	Violet	10	10	PATCH PANEL "A" PORT 10	NO CONNECTION (LATERAL STRANDS COILED IN SPLICE CLOSURE)
	Rose	11	11	PATCH PANEL "A" PORT 11 (JUMPERED TO LAYER III ETHERNET SWITCH)	DCF-NO-003 (WB), FIBER 55
	Aqua	12	12	PATCH PANEL "A" PORT 12 (JUMPERED TO LAYER III ETHERNET SWITCH)	DCF-NO-003 (EB), FIBER 55
ORANGE	Blue	1	13	COILED IN FIBER OPTIC INTERCONNECT CENTER	NO CONNECTION (LATERAL STRANDS COILED IN SPLICE CLOSURE)
	Orange	2	14	COILED IN FIBER OPTIC INTERCONNECT CENTER	NO CONNECTION (LATERAL STRANDS COILED IN SPLICE CLOSURE)
	Green	3	15	COILED IN FIBER OPTIC INTERCONNECT CENTER	NO CONNECTION (LATERAL STRANDS COILED IN SPLICE CLOSURE)
	Brown	4	16	COILED IN FIBER OPTIC INTERCONNECT CENTER	NO CONNECTION (LATERAL STRANDS COILED IN SPLICE CLOSURE)
	Slate	5	17	COILED IN FIBER OPTIC INTERCONNECT CENTER	NO CONNECTION (LATERAL STRANDS COILED IN SPLICE CLOSURE)
	White	6	18	COILED IN FIBER OPTIC INTERCONNECT CENTER	NO CONNECTION (LATERAL STRANDS COILED IN SPLICE CLOSURE)
	Red	7	19	COILED IN FIBER OPTIC INTERCONNECT CENTER	NO CONNECTION (LATERAL STRANDS COILED IN SPLICE CLOSURE)
	Black	8	20	COILED IN FIBER OPTIC INTERCONNECT CENTER	NO CONNECTION (LATERAL STRANDS COILED IN SPLICE CLOSURE)
	Yellow	9	21	COILED IN FIBER OPTIC INTERCONNECT CENTER	NO CONNECTION (LATERAL STRANDS COILED IN SPLICE CLOSURE)
	Violet	10	22	COILED IN FIBER OPTIC INTERCONNECT CENTER	NO CONNECTION (LATERAL STRANDS COILED IN SPLICE CLOSURE)
	Rose	11	23	COILED IN FIBER OPTIC INTERCONNECT CENTER	NO CONNECTION (LATERAL STRANDS COILED IN SPLICE CLOSURE)
	Aqua	12	24	COILED IN FIBER OPTIC INTERCONNECT CENTER	NO CONNECTION (LATERAL STRANDS COILED IN SPLICE CLOSURE)



© 2023 KIMLEY-HORN AND ASSOCIATES, INC.
4001 HWY 10 ROAD, SUITE 600
WARREN, IL 6. 0585
PHONE: 815.477.4555
WWW.KIMLEY-HORN.COM

USER NAME	=	
PLOT SCALE	=	
PLOT DATE	=	

DESIGNED	-	
DRAWN	-	
CHECKED	-	
DATE	-	

REVISED	-	
REVISED	-	
REVISED	-	
REVISED	-	

STATE OF ILLINOIS
DEPARTMENT OF TRANSPORTATION

FIBER OPTIC LATERAL CABLE SPLICE ASSIGNMENTS
LCF-NO-003m

SCALE:	SHEET	OF	SHEETS	STA.	TO	STA.
--------	-------	----	--------	------	----	------

F.A.P. RTE.	SECTION	COUNTY	TOTAL SHEETS	SHEET NO.
307	2020-263-SUR,SW&TS	DUPAGE	529	473
CONTRACT NO. 62N33				
		ILLINOIS	FED. AID PROJECT	

LATERAL CABLE FIBER ASSIGNMENTS				ORIGINATION	CAB-NO-015C
LATERAL CABLE DESIGNATION			LCF-NO-003n	DESTINATION	CMV-NO-015H
BUFFER TUBE	FIBER	FIBER NO.	CABINET CONNECTIONS	DISTRIBUTION CABLE CONNECTIONS	
BLUE	Blue	1	PATCH PANEL "A" PORT 1 (JUMPERED TO LAYER II ETHERNET SWITCH)	DCF-NO-003 (WB), FIBER 35	
	Orange	2	PATCH PANEL "A" PORT 2 (JUMPERED TO LAYER II ETHERNET SWITCH)	DCF-NO-003 (WB), FIBER 36	
	Green	3	PATCH PANEL "A" PORT 3	NO CONNECTION (LATERAL STRANDS COILED IN SPLICE CLOSURE)	
	Brown	4	PATCH PANEL "A" PORT 4	NO CONNECTION (LATERAL STRANDS COILED IN SPLICE CLOSURE)	
	Slate	5	PATCH PANEL "A" PORT 5	NO CONNECTION (LATERAL STRANDS COILED IN SPLICE CLOSURE)	
	White	6	PATCH PANEL "A" PORT 6	NO CONNECTION (LATERAL STRANDS COILED IN SPLICE CLOSURE)	
	Red	7	PATCH PANEL "A" PORT 7 (JUMPERED TO LAYER II ETHERNET SWITCH)	DCF-NO-003 (EB), FIBER 35	
	Black	8	PATCH PANEL "A" PORT 8 (JUMPERED TO LAYER II ETHERNET SWITCH)	DCF-NO-003 (EB), FIBER 36	
	Yellow	9	PATCH PANEL "A" PORT 9	NO CONNECTION (LATERAL STRANDS COILED IN SPLICE CLOSURE)	
	Violet	10	PATCH PANEL "A" PORT 10	NO CONNECTION (LATERAL STRANDS COILED IN SPLICE CLOSURE)	
	Rose	11	PATCH PANEL "A" PORT 11	NO CONNECTION (LATERAL STRANDS COILED IN SPLICE CLOSURE)	
	Aqua	12	PATCH PANEL "A" PORT 12	NO CONNECTION (LATERAL STRANDS COILED IN SPLICE CLOSURE)	
ORANGE	Blue	13	COILED IN FIBER OPTIC INTERCONNECT CENTER	NO CONNECTION (LATERAL STRANDS COILED IN SPLICE CLOSURE)	
	Orange	14	COILED IN FIBER OPTIC INTERCONNECT CENTER	NO CONNECTION (LATERAL STRANDS COILED IN SPLICE CLOSURE)	
	Green	15	COILED IN FIBER OPTIC INTERCONNECT CENTER	NO CONNECTION (LATERAL STRANDS COILED IN SPLICE CLOSURE)	
	Brown	16	COILED IN FIBER OPTIC INTERCONNECT CENTER	NO CONNECTION (LATERAL STRANDS COILED IN SPLICE CLOSURE)	
	Slate	17	COILED IN FIBER OPTIC INTERCONNECT CENTER	NO CONNECTION (LATERAL STRANDS COILED IN SPLICE CLOSURE)	
	White	18	COILED IN FIBER OPTIC INTERCONNECT CENTER	NO CONNECTION (LATERAL STRANDS COILED IN SPLICE CLOSURE)	
	Red	19	COILED IN FIBER OPTIC INTERCONNECT CENTER	NO CONNECTION (LATERAL STRANDS COILED IN SPLICE CLOSURE)	
	Black	20	COILED IN FIBER OPTIC INTERCONNECT CENTER	NO CONNECTION (LATERAL STRANDS COILED IN SPLICE CLOSURE)	
	Yellow	21	COILED IN FIBER OPTIC INTERCONNECT CENTER	NO CONNECTION (LATERAL STRANDS COILED IN SPLICE CLOSURE)	
	Violet	10	COILED IN FIBER OPTIC INTERCONNECT CENTER	NO CONNECTION (LATERAL STRANDS COILED IN SPLICE CLOSURE)	
	Rose	11	COILED IN FIBER OPTIC INTERCONNECT CENTER	NO CONNECTION (LATERAL STRANDS COILED IN SPLICE CLOSURE)	
	Aqua	12	COILED IN FIBER OPTIC INTERCONNECT CENTER	NO CONNECTION (LATERAL STRANDS COILED IN SPLICE CLOSURE)	

 © 2022 KIMLEY-HORN AND ASSOCIATES, INC. 4001 WILBUR D. HOWE, SUITE 600 WARREN, IL 6 60855 PHONE: 630.467.6000 WWW.KH-IL.COM	USER NAME =	DESIGNED -	REVISED -	STATE OF ILLINOIS DEPARTMENT OF TRANSPORTATION	FIBER OPTIC LATERAL CABLE SPLICE ASSIGNMENTS LCF-NO-003n					F.A.P. RTE.	SECTION	COUNTY	TOTAL SHEETS	SHEET NO.
	PLOT SCALE =	DRAWN -	REVISED -							307	2020-263-SUR,SW&TS	DUPAGE	529	474
	PLOT DATE =	CHECKED -	REVISED -		SCALE: SHEET OF SHEETS STA. TO STA.					CONTRACT NO. 62N33				
		DATE	REVISED -							ILLINOIS FED. AID PROJECT				

MODEL: Default
FILE: Kimley-Horn\Bentley.com\k-h-gp-d\Documents\01 Active Projects\MW-CUS-16895\100 - IL 64\Phase 1\12 Design\CAD\Plan Sheets\Communications\West Corridor\108121-eh-cmm-lateral-25.kim.dgn

LATERAL CABLE FIBER ASSIGNMENTS				ORIGINATION	CAB-NO-016
LATERAL CABLE DESIGNATION			LCF-NO-003o	DESTINATION	CMV-NO-016A
BUFFER TUBE	FIBER	FIBER NO.	CABINET CONNECTIONS	DISTRIBUTION CABLE CONNECTIONS	
BLUE	Blue	1	1	PATCH PANEL "A" PORT 1 (JUMPERED TO LAYER II ETHERNET SWITCH)	DCF-NO-003 (WB), FIBER 33
	Orange	2	2	PATCH PANEL "A" PORT 2 (JUMPERED TO LAYER II ETHERNET SWITCH)	DCF-NO-003 (WB), FIBER 34
	Green	3	3	PATCH PANEL "A" PORT 3	NO CONNECTION (LATERAL STRANDS COILED IN SPLICE CLOSURE)
	Brown	4	4	PATCH PANEL "A" PORT 4	NO CONNECTION (LATERAL STRANDS COILED IN SPLICE CLOSURE)
	Slate	5	5	PATCH PANEL "A" PORT 5	NO CONNECTION (LATERAL STRANDS COILED IN SPLICE CLOSURE)
	White	6	6	PATCH PANEL "A" PORT 6	NO CONNECTION (LATERAL STRANDS COILED IN SPLICE CLOSURE)
	Red	7	7	PATCH PANEL "A" PORT 7 (JUMPERED TO LAYER II ETHERNET SWITCH)	DCF-NO-003 (EB), FIBER 33
	Black	8	8	PATCH PANEL "A" PORT 8 (JUMPERED TO LAYER II ETHERNET SWITCH)	DCF-NO-003 (EB), FIBER 34
	Yellow	9	9	PATCH PANEL "A" PORT 9	NO CONNECTION (LATERAL STRANDS COILED IN SPLICE CLOSURE)
	Violet	10	10	PATCH PANEL "A" PORT 10	NO CONNECTION (LATERAL STRANDS COILED IN SPLICE CLOSURE)
	Rose	11	11	PATCH PANEL "A" PORT 11	NO CONNECTION (LATERAL STRANDS COILED IN SPLICE CLOSURE)
	Aqua	12	12	PATCH PANEL "A" PORT 12	NO CONNECTION (LATERAL STRANDS COILED IN SPLICE CLOSURE)
ORANGE	Blue	1	13	COILED IN FIBER OPTIC INTERCONNECT CENTER	NO CONNECTION (LATERAL STRANDS COILED IN SPLICE CLOSURE)
	Orange	2	14	COILED IN FIBER OPTIC INTERCONNECT CENTER	NO CONNECTION (LATERAL STRANDS COILED IN SPLICE CLOSURE)
	Green	3	15	COILED IN FIBER OPTIC INTERCONNECT CENTER	NO CONNECTION (LATERAL STRANDS COILED IN SPLICE CLOSURE)
	Brown	4	16	COILED IN FIBER OPTIC INTERCONNECT CENTER	NO CONNECTION (LATERAL STRANDS COILED IN SPLICE CLOSURE)
	Slate	5	17	COILED IN FIBER OPTIC INTERCONNECT CENTER	NO CONNECTION (LATERAL STRANDS COILED IN SPLICE CLOSURE)
	White	6	18	COILED IN FIBER OPTIC INTERCONNECT CENTER	NO CONNECTION (LATERAL STRANDS COILED IN SPLICE CLOSURE)
	Red	7	19	COILED IN FIBER OPTIC INTERCONNECT CENTER	NO CONNECTION (LATERAL STRANDS COILED IN SPLICE CLOSURE)
	Black	8	20	COILED IN FIBER OPTIC INTERCONNECT CENTER	NO CONNECTION (LATERAL STRANDS COILED IN SPLICE CLOSURE)
	Yellow	9	21	COILED IN FIBER OPTIC INTERCONNECT CENTER	NO CONNECTION (LATERAL STRANDS COILED IN SPLICE CLOSURE)
	Violet	10	22	COILED IN FIBER OPTIC INTERCONNECT CENTER	NO CONNECTION (LATERAL STRANDS COILED IN SPLICE CLOSURE)
	Rose	11	23	COILED IN FIBER OPTIC INTERCONNECT CENTER	NO CONNECTION (LATERAL STRANDS COILED IN SPLICE CLOSURE)
	Aqua	12	24	COILED IN FIBER OPTIC INTERCONNECT CENTER	NO CONNECTION (LATERAL STRANDS COILED IN SPLICE CLOSURE)



© 2023 KIMLEY-HORN AND ASSOCIATES, INC.

4001 HWY 10 ROAD, SUITE 600

WARREN, IL 6. 60555

PHONE: 815.447.4555



WWW.KIMLEY-HORN.COM

USER NAME	=	DESIGNED	-	REVISED	-
		DRAWN	-	REVISED	-
PLOT SCALE	=	CHECKED	-	REVISED	-
PLOT DATE	=	DATE	-	REVISED	-

STATE OF ILLINOIS
DEPARTMENT OF TRANSPORTATION

FIBER OPTIC LATERAL CABLE SPLICE ASSIGNMENTS				
LCF-NO-003o				
SCALE:	SHEET	OF	SHEETS	STA. TO STA.


F.A.P. RTE.	SECTION	COUNTY	TOTAL SHEETS	SHEET NO.
307	2020-263-SUR,SW&TS	DUPAGE	529	475
CONTRACT NO. 62N33				
		ILLINOIS	FED. AID PROJECT	

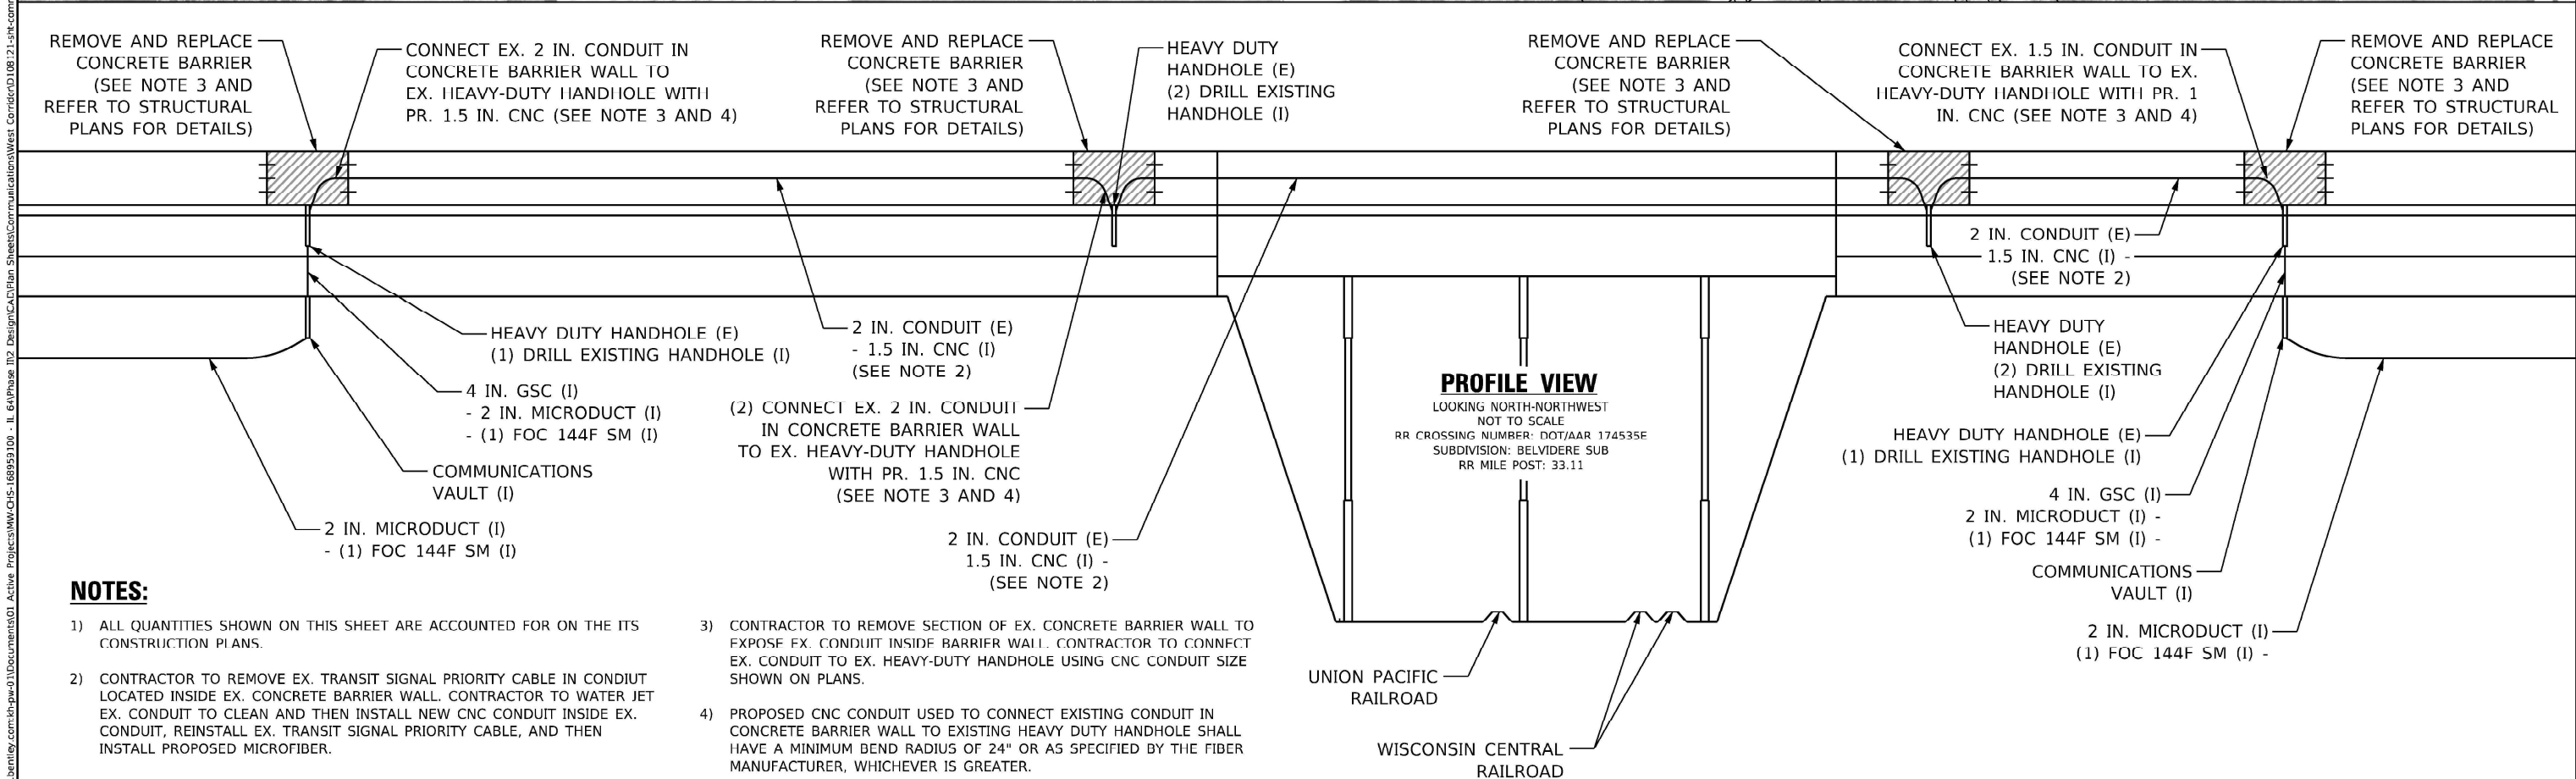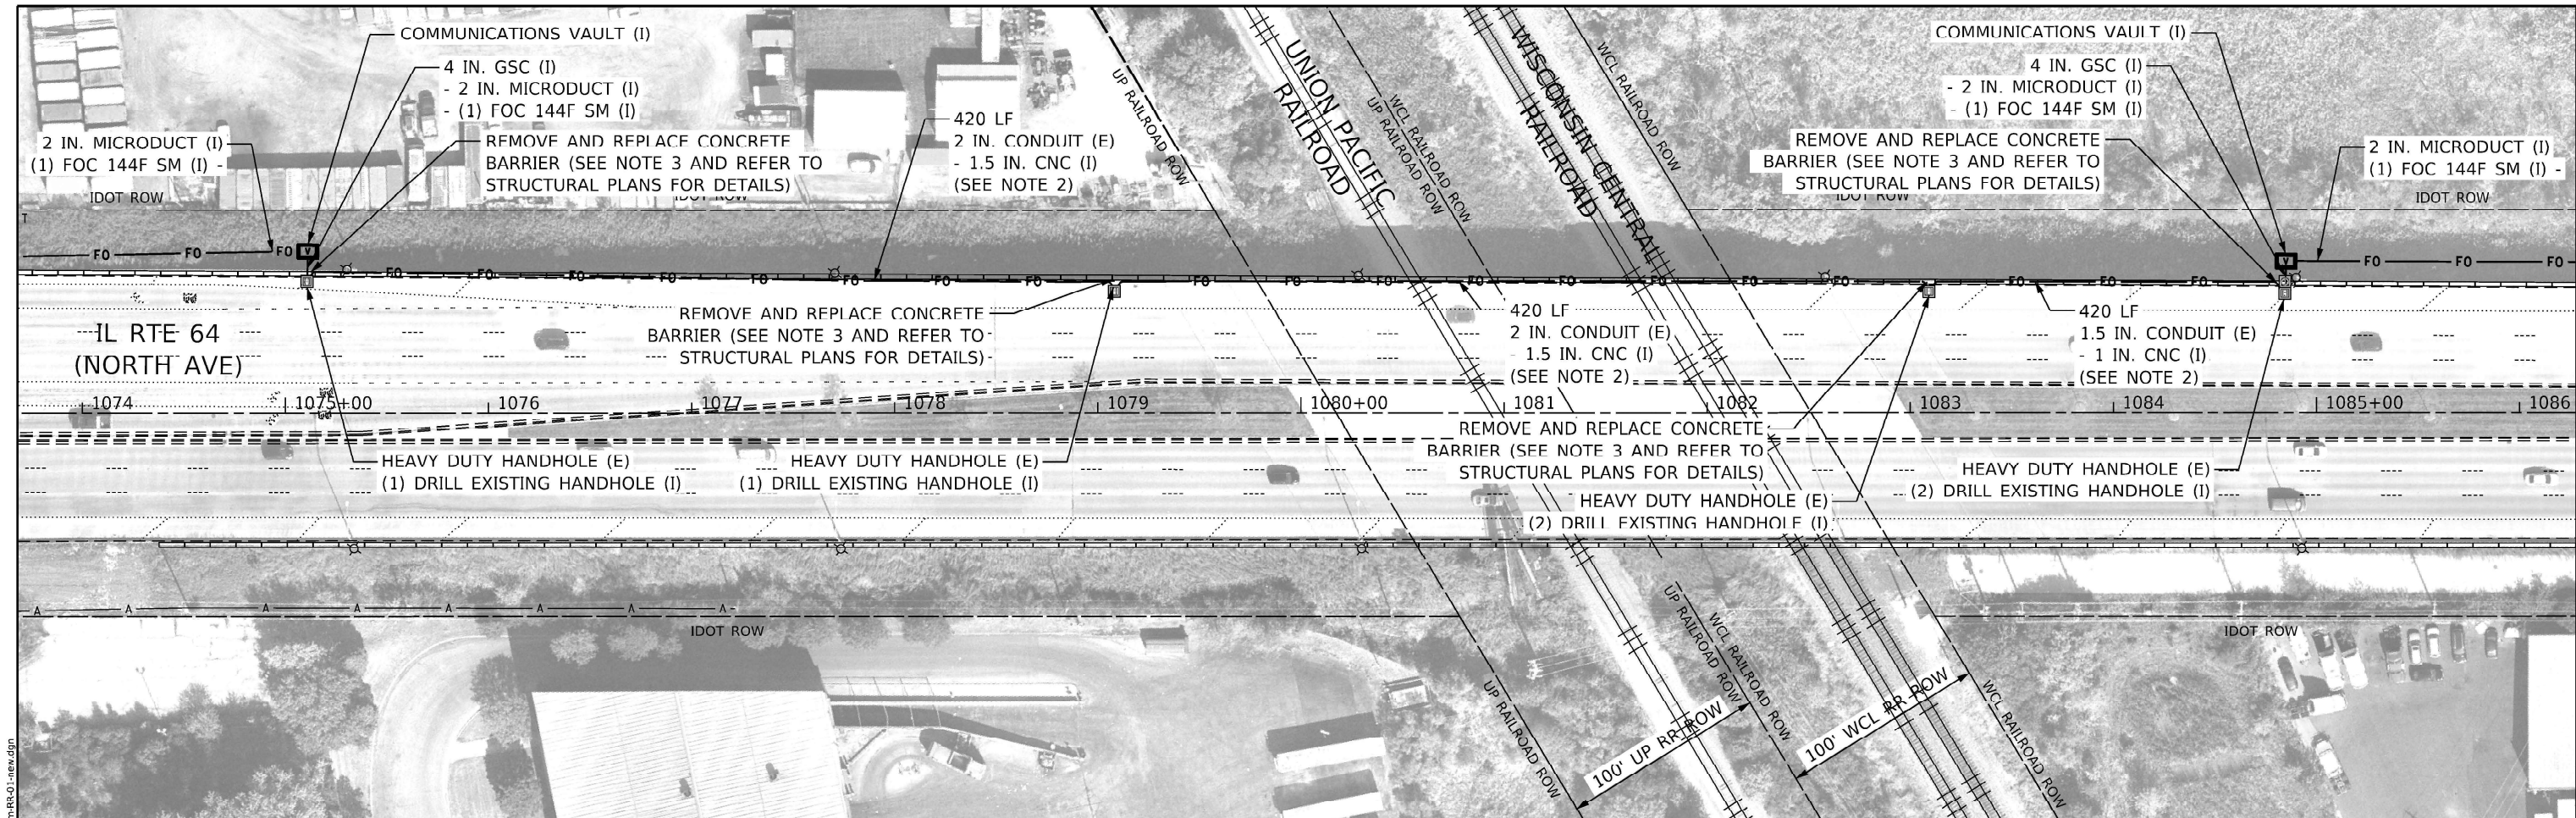

NOTES:

- ALL QUANTITIES SHOWN ON THIS SHEET ARE ACCOUNTED FOR ON THE ITS CONSTRUCTION PLANS.
- CONTRACTOR TO REMOVE EX. TRANSIT SIGNAL PRIORITY CABLE IN CONDUIT LOCATED INSIDE EX. CONCRETE BARRIER WALL. CONTRACTOR TO WATER JET EX. CONDUIT TO CLEAN AND THEN INSTALL NEW CNC CONDUIT INSIDE EX. CONDUIT, REINSTALL EX. TRANSIT SIGNAL PRIORITY CABLE, AND THEN INSTALL PROPOSED MICROFIBER.
- CONTRACTOR TO REMOVE SECTION OF EX. CONCRETE BARRIER WALL TO EXPOSE EX. CONDUIT INSIDE BARRIER WALL. CONTRACTOR TO CONNECT EX. CONDUIT TO EX. HEAVY-DUTY HANDHOLE USING CNC CONDUIT SIZE SHOWN ON PLANS.
- PROPOSED CNC CONDUIT USED TO CONNECT EXISTING CONDUIT IN CONCRETE BARRIER WALL TO EXISTING HEAVY DUTY HANDHOLE SHALL HAVE A MINIMUM BEND RADIUS OF 24" OR AS SPECIFIED BY THE FIBER MANUFACTURER, WHICHEVER IS GREATER.



FILE NAME: DWG: Kimley»Horn © 2020 KIMLEY HORN AND ASSOCIATES, INC. 4000 WILSON DRIVE, SUITE 200 WARRENVILLE, IL 60088 PHONE: 630-487-5500 WWW.KIMLEY-HORN.COM	USER NAME =	DESIGNED -	REVISED -	STATE OF ILLINOIS DEPARTMENT OF TRANSPORTATION	RAILROAD CROSSING DETAIL IL 64 (NORTH AVE) OVER WISCONSIN CENTRAL RAILROAD				F.A.P. RTE.	SECTION	COUNTY	TOTAL SHEETS	SHEET NO.
	DRAWN -	DRAWN -	REVISED -						307	2020-263-SUR-SW&TS	DUPAGE	529	476
	PLOT SCALE =	CHECKED -	REVISED -		CONTRACT NO. 62N33								
	PLOT DATE =	DATE -	REVISED -		ILLINOIS FED. AID PROJECT								
					SCALE: 1" = 40'	SHEET	OF	SHEETS	STA.	TO	STA.		

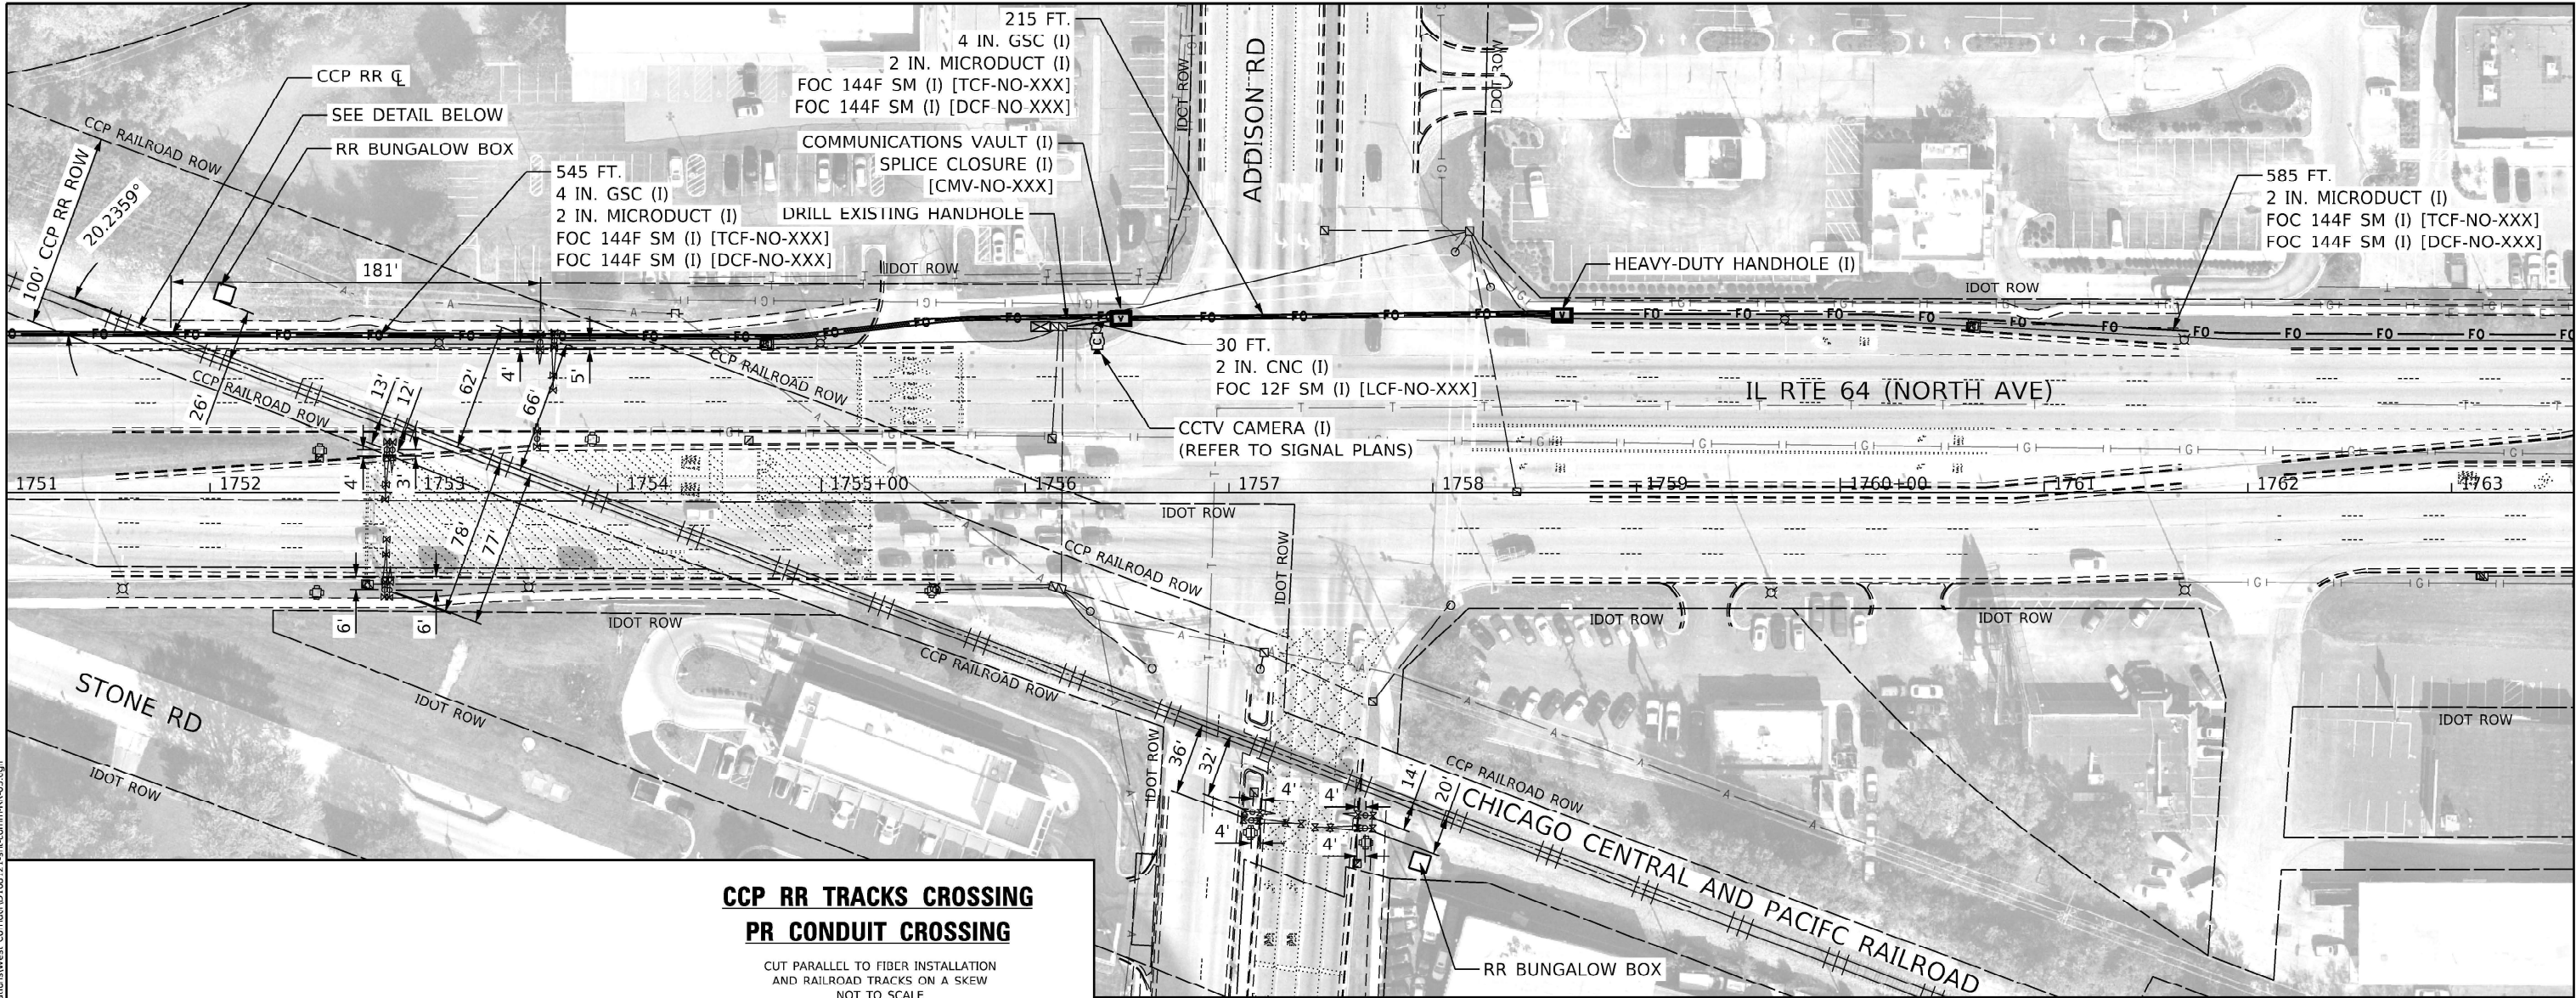

**CCP RR TRACKS CROSSING
PR CONDUIT CROSSING**

CUT PARALLEL TO FIBER INSTALLATION
AND RAILROAD TRACKS ON A SKEW
NOT TO SCALE
RR CROSSING NUMBER: DOT/AAR 28 9861D
SUBDIVISION: FREEPORT SUB
RR MILE POST: 22.40

SECTION A-A
NOT TO SCALE

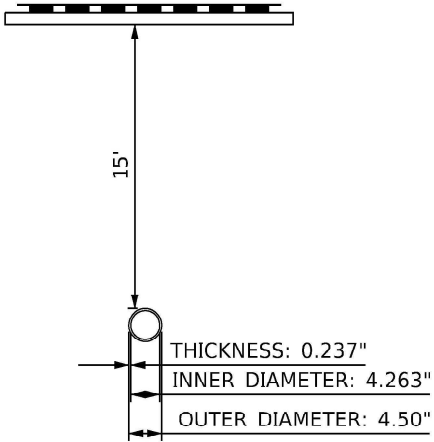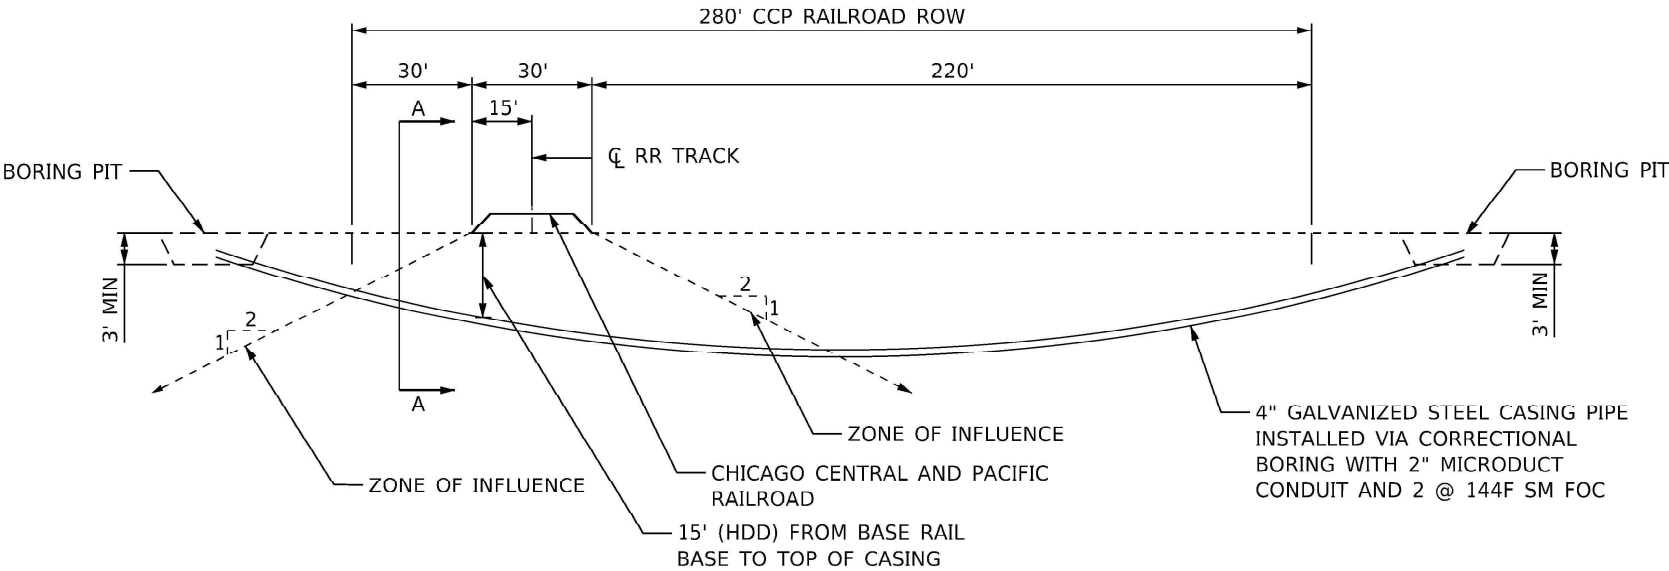

MODEL: Default
FILE: I:\Bentley\p1\h-pw-bentley.com-bhp-w-01\Documents\01 Active Projects\MM\CHS-168953\100 - IL 64\Phase 1\12 Design\CA\Plan Sheets\Communications\West Corridor\0108-21-11-11-comm-RR-03.dgn

KimleyHorn
© 2020 KIMLEY HORN AND ASSOCIATES, INC.
4000 WILSON BLVD., SUITE 200
WARRENVILLE, IL 60089
PHONE: 847-487-5500
WWW.KIMLEYHORN.COM



USER NAME =	DESIGNED -	REVISED -
	DRAWN -	REVISED -
PLOT SCALE =	CHECKED -	REVISED -
PLOT DATE =	DATE -	REVISED -

**STATE OF ILLINOIS
DEPARTMENT OF TRANSPORTATION**



**RAILROAD CROSSING DETAIL
IL 64 (NORTH AVE) AND CHICAGO CENTRAL AND PACIFIC RAILROAD**

SCALE: 1" = 40' SHEET OF SHEETS STA. TO STA.



F.A.P. RTE.	SECTION	COUNTY	TOTAL SHEETS	SHEET NO.
307	2020-263-SUR.SW&TS	DUPAGE	529	477
CONTRACT NO. 62N33				
ILLINOIS FED. AID PROJECT				

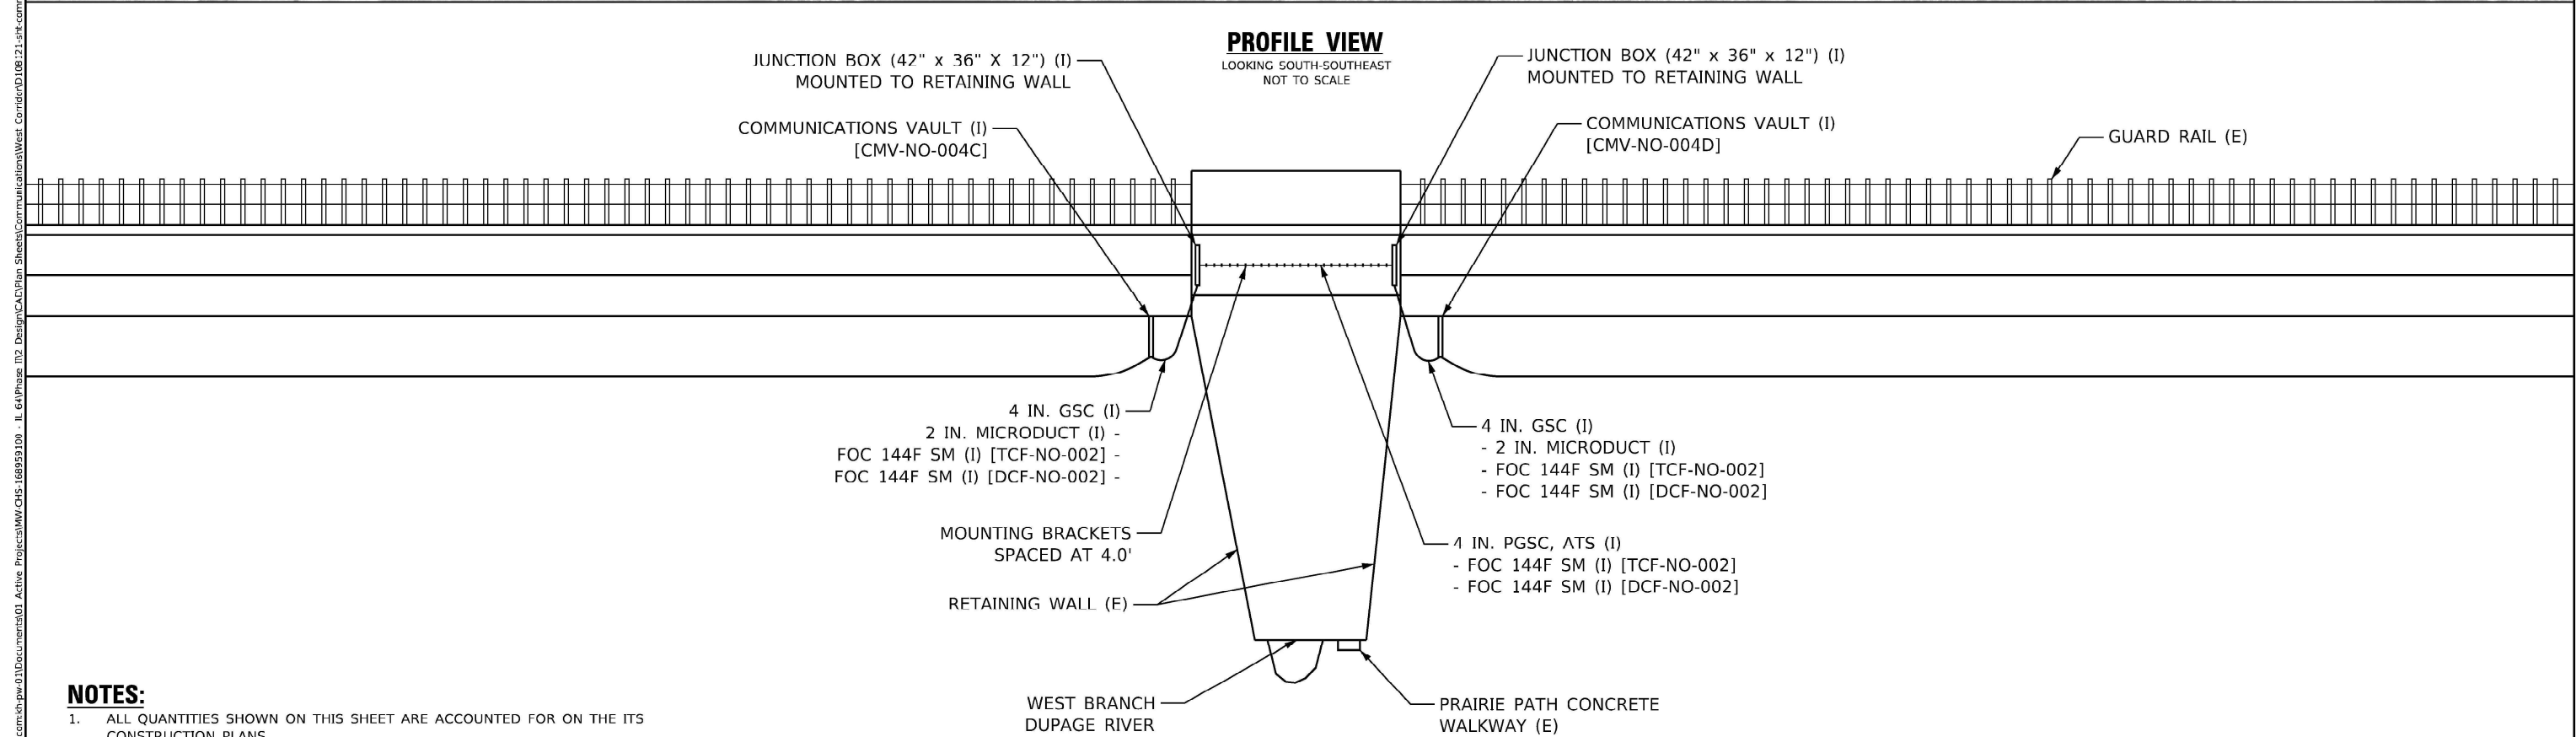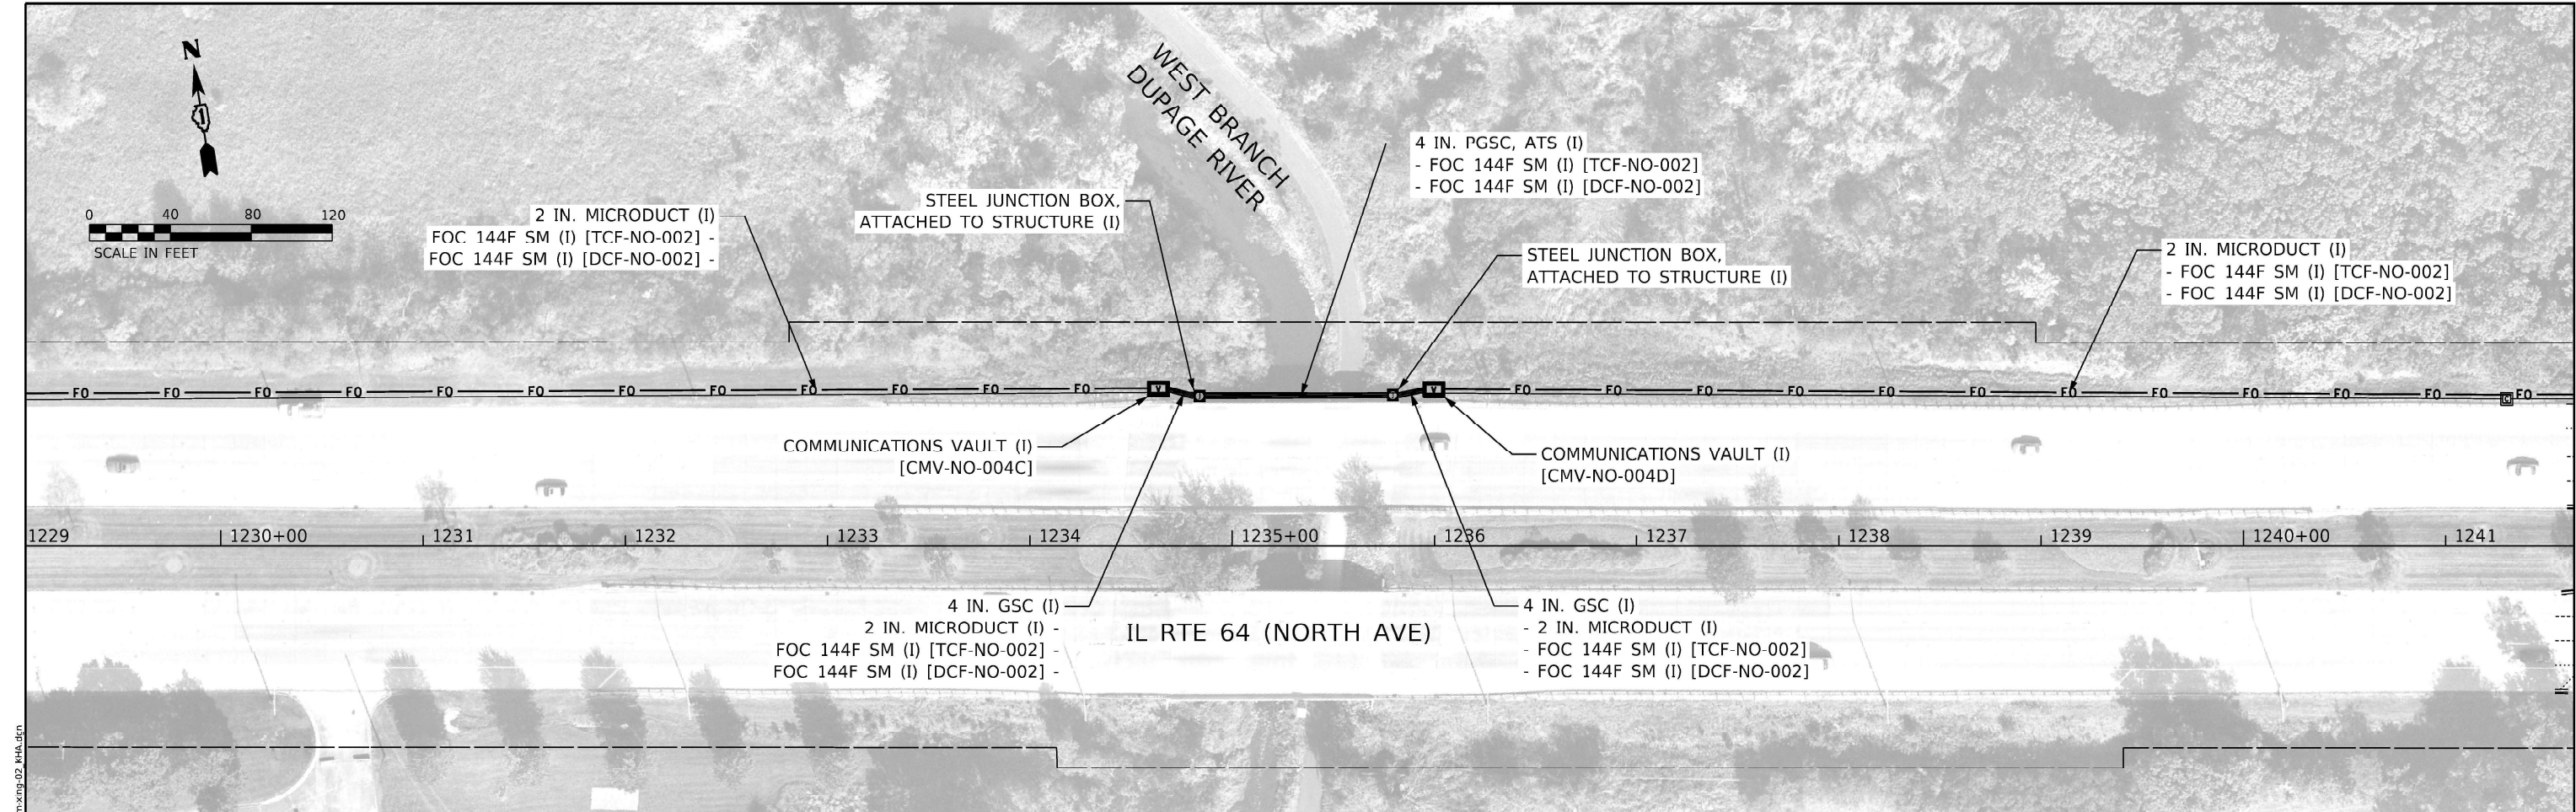

- NOTES:**
1. ALL QUANTITIES SHOWN ON THIS SHEET ARE ACCOUNTED FOR ON THE ITS CONSTRUCTION PLANS.
 2. CONDUIT HANGERS AND MOUNTING BRACKETS SHALL BE SPACED AT 4 FT. MAXIMUM.

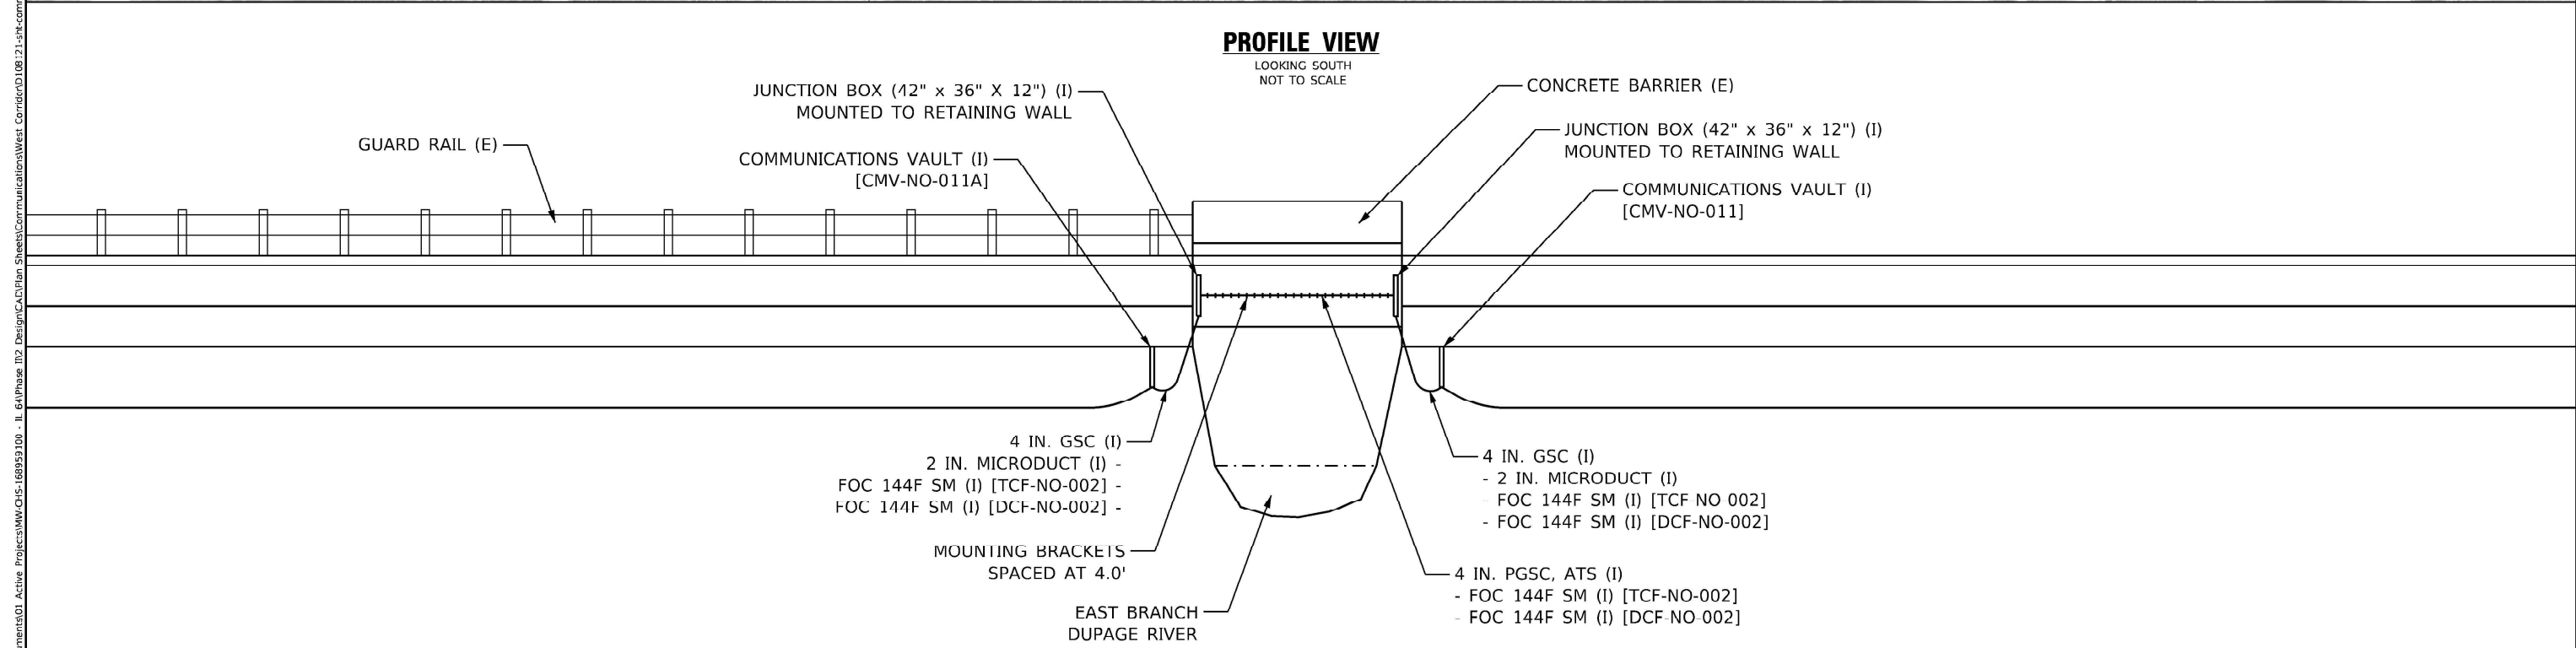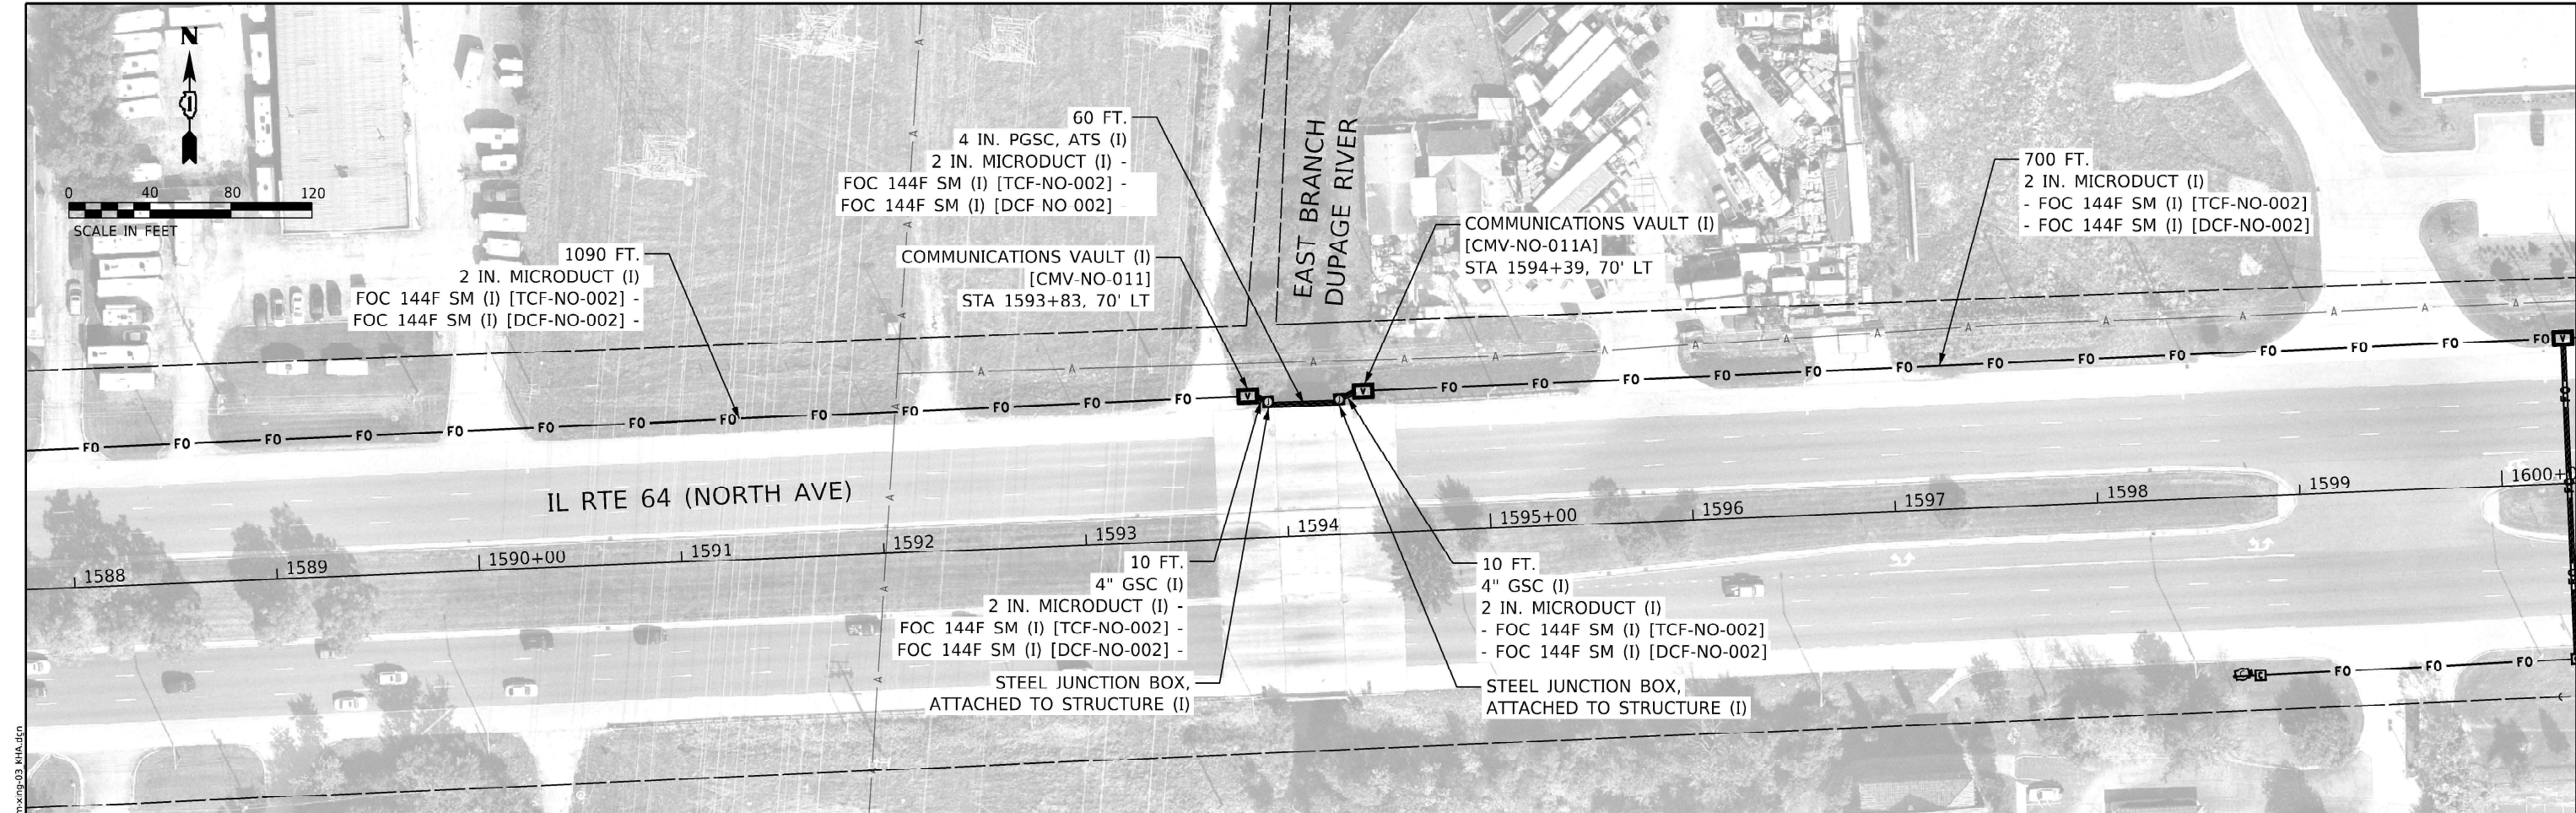


- NOTES:**
1. ALL QUANTITIES SHOWN ON THIS SHEET ARE ACCOUNTED FOR ON THE ITS CONSTRUCTION PLANS.
 2. CONDUIT HANGERS AND MOUNTING BRACKETS SHALL BE SPACED AT 4 FT. MAXIMUM.

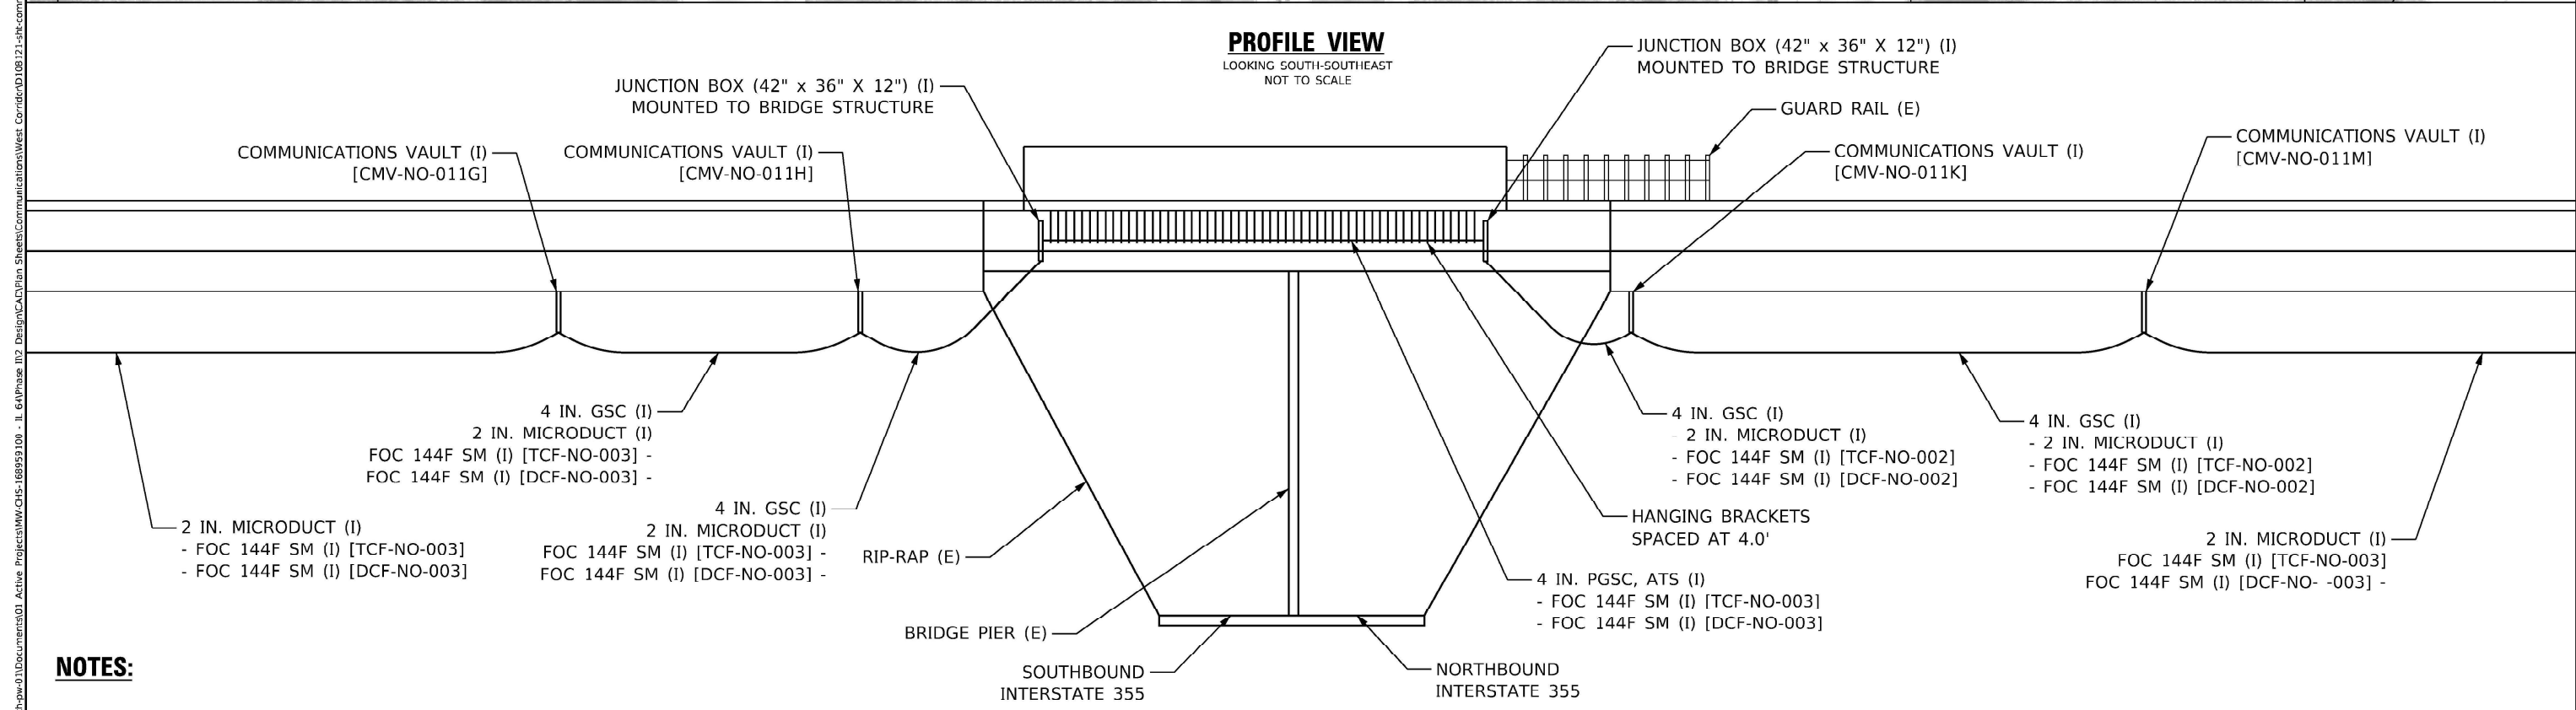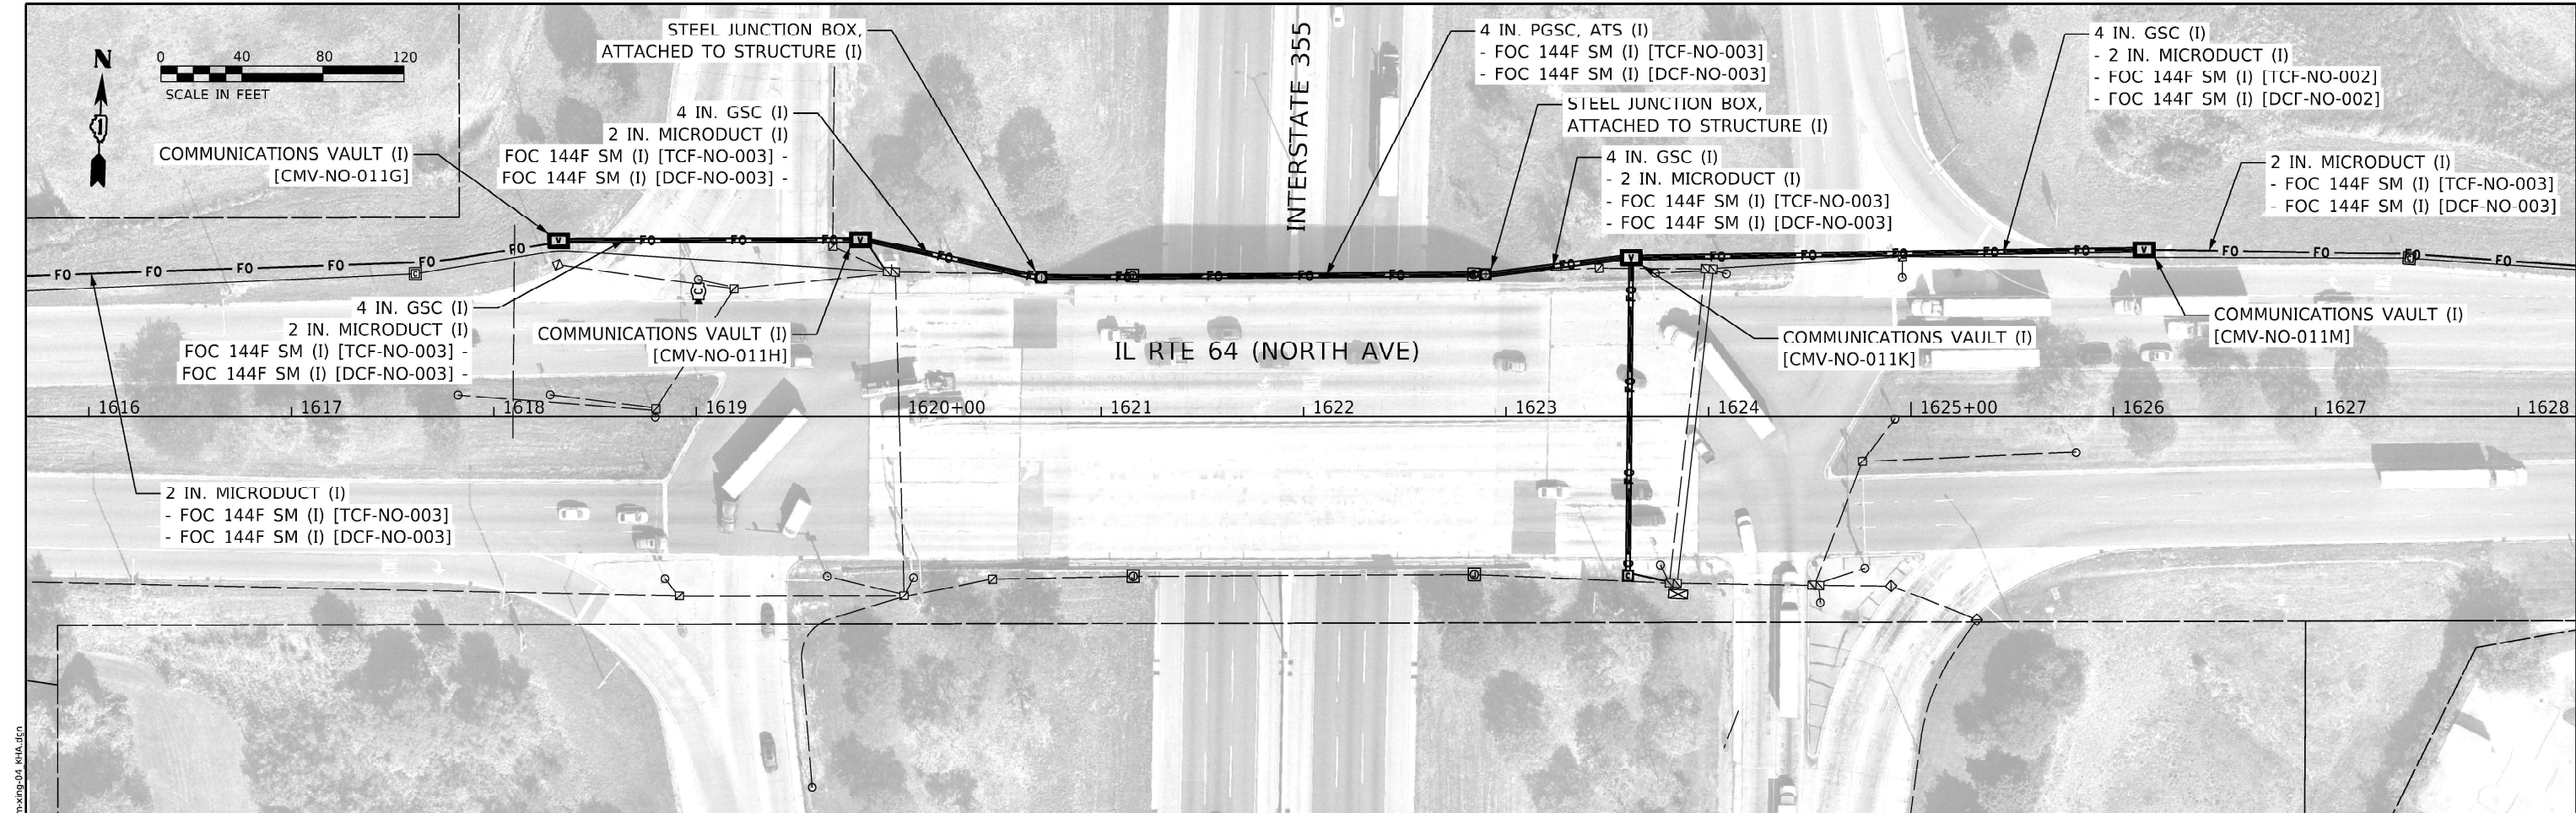



NOTES:

- ALL QUANTITIES SHOWN ON THIS SHEET ARE ACCOUNTED FOR ON THE ITS CONSTRUCTION PLANS.
- CONDUIT HANGERS AND MOUNTING BRACKETS SHALL BE SPACED AT 4 FT. MAXIMUM.

MODEL: Default
FILE: I:\Users\paw.bentley.com\khpw\01\Documents\01 Active Projects\WW-GHS-160953\100 - IL 64 Phase 1112 Design\CACT Plan Sheets\Communications\West Corridor\108 21-sh-dms-03.kia.dgn

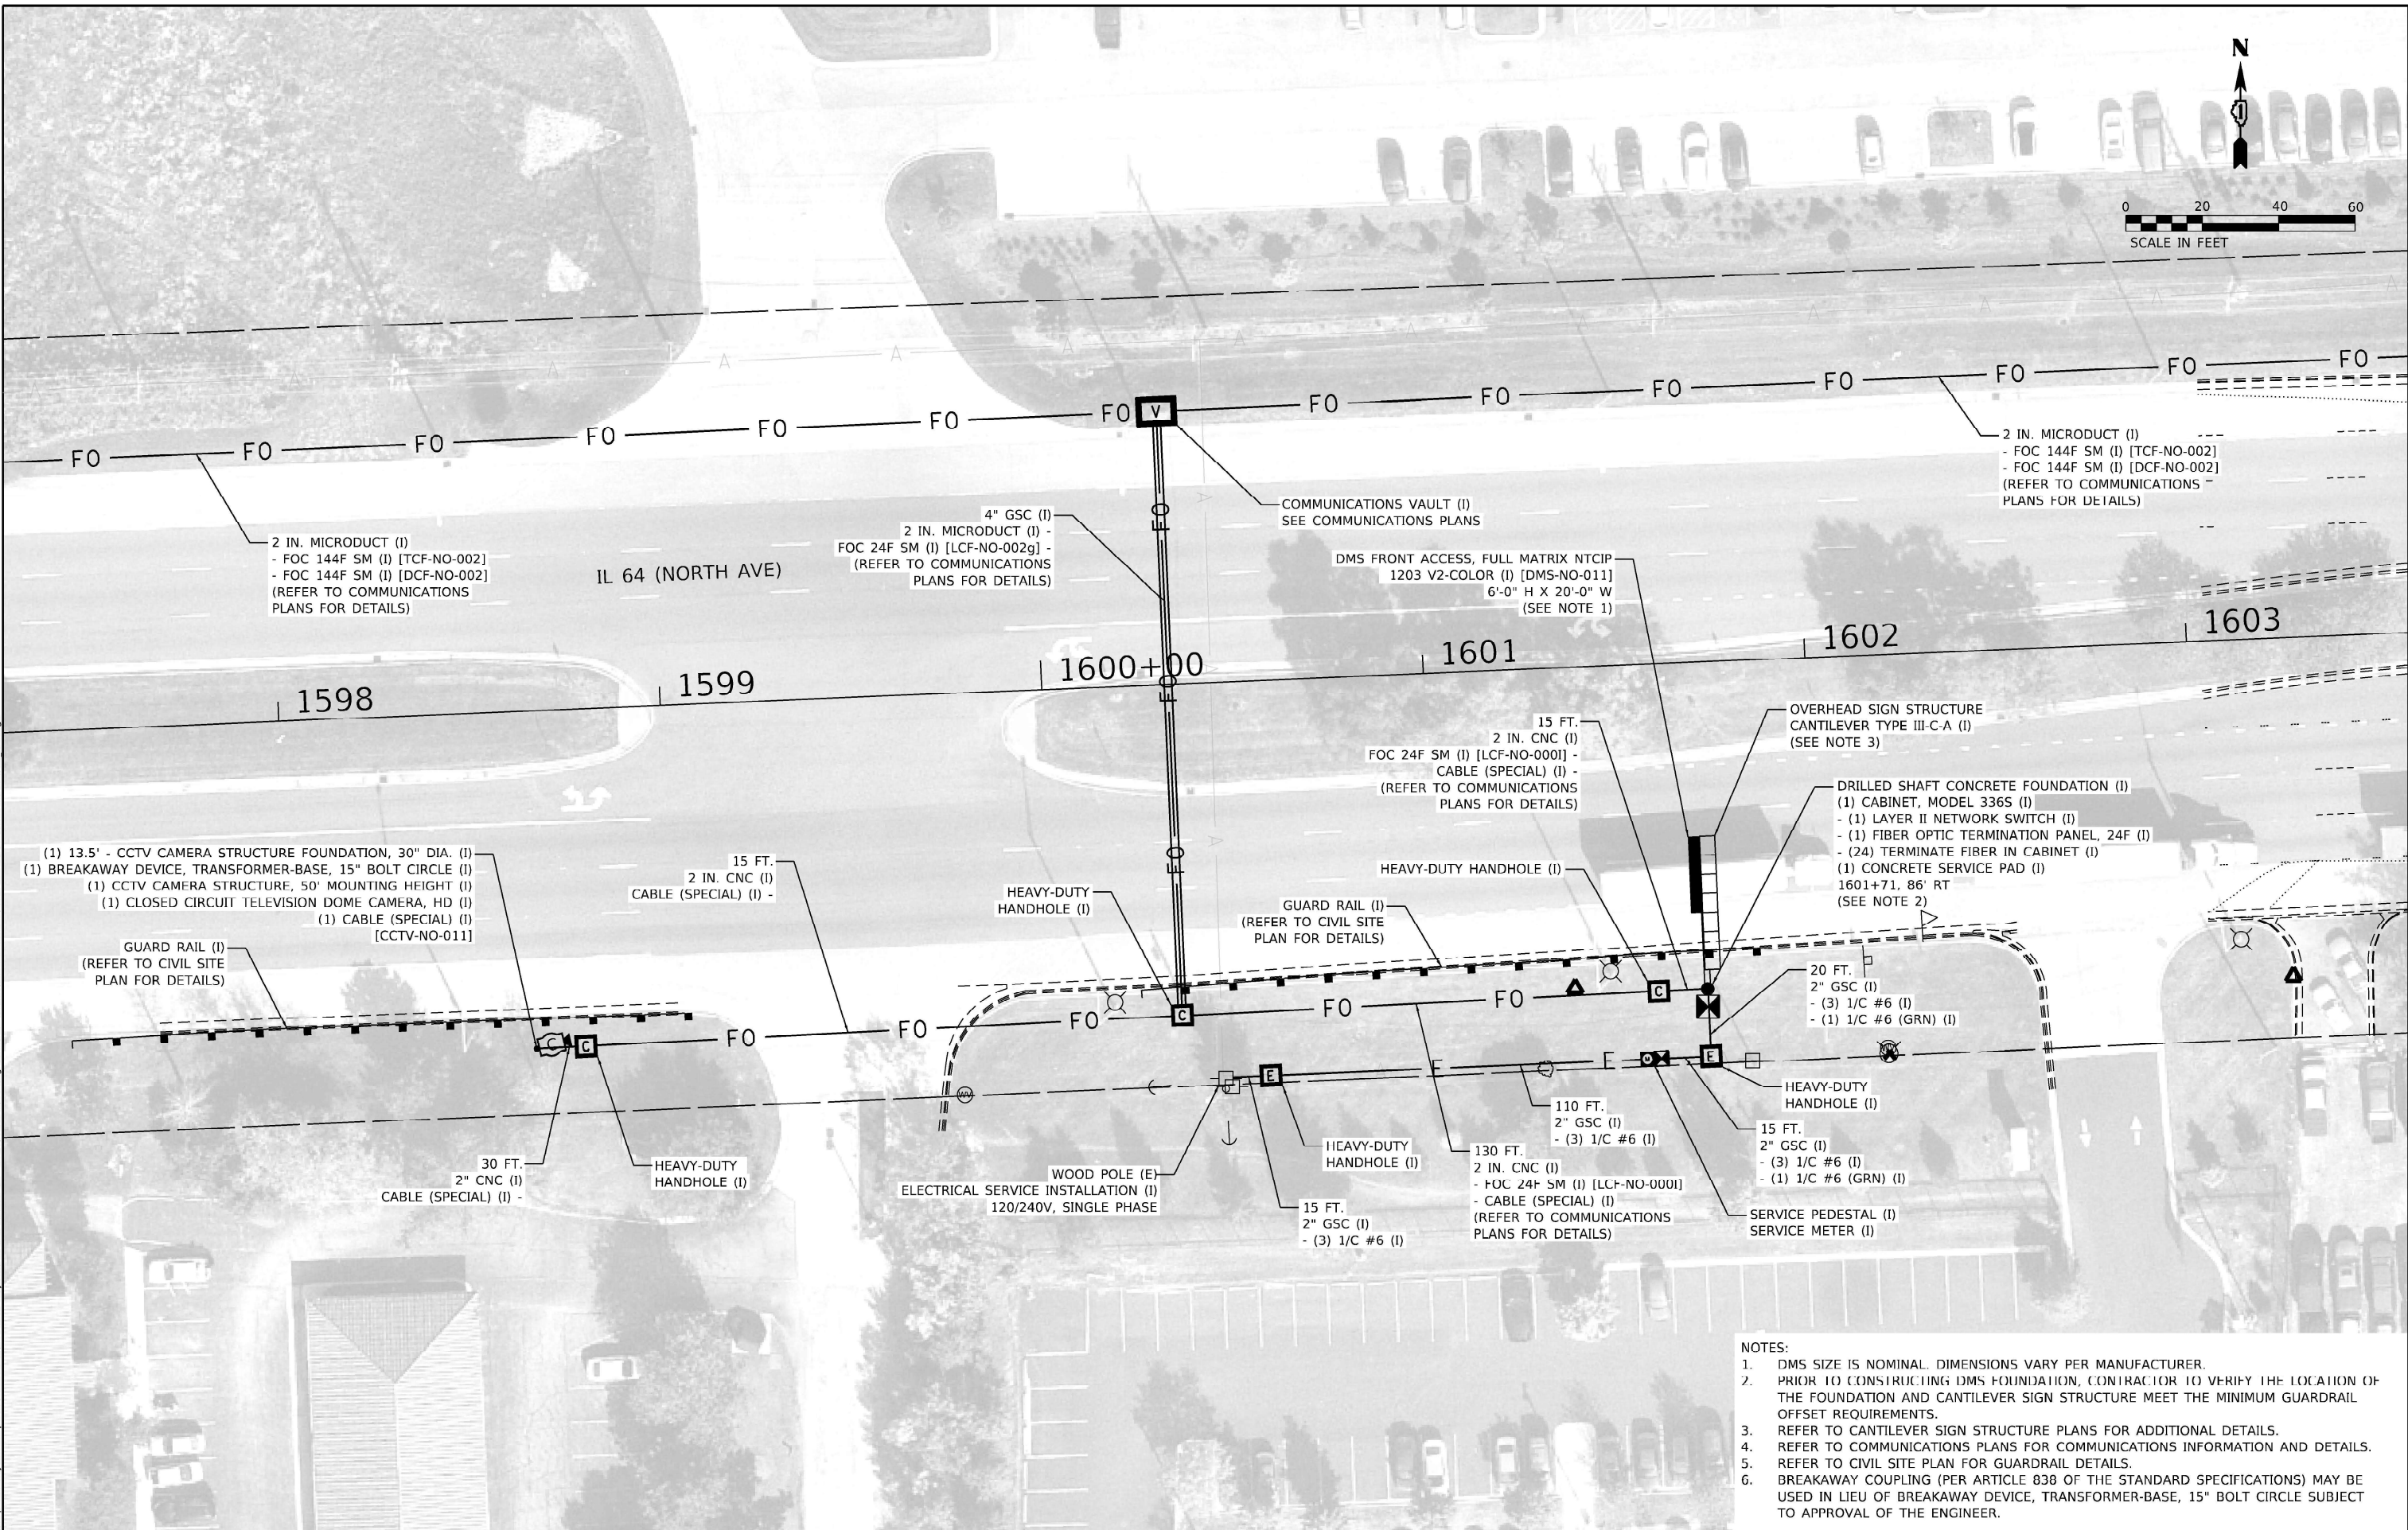

- NOTES:
- DMS SIZE IS NOMINAL. DIMENSIONS VARY PER MANUFACTURER.
 - PRIOR TO CONSTRUCTING DMS FOUNDATION, CONTRACTOR TO VERIFY THE LOCATION OF THE FOUNDATION AND CANTILEVER SIGN STRUCTURE MEET THE MINIMUM GUARDRAIL OFFSET REQUIREMENTS.
 - REFER TO CANTILEVER SIGN STRUCTURE PLANS FOR ADDITIONAL DETAILS.
 - REFER TO COMMUNICATIONS PLANS FOR COMMUNICATIONS INFORMATION AND DETAILS.
 - REFER TO CIVIL SITE PLAN FOR GUARDRAIL DETAILS.
 - BREAKAWAY COUPLING (PER ARTICLE 838 OF THE STANDARD SPECIFICATIONS) MAY BE USED IN LIEU OF BREAKAWAY DEVICE, TRANSFORMER-BASE, 15" BOLT CIRCLE SUBJECT TO APPROVAL OF THE ENGINEER.

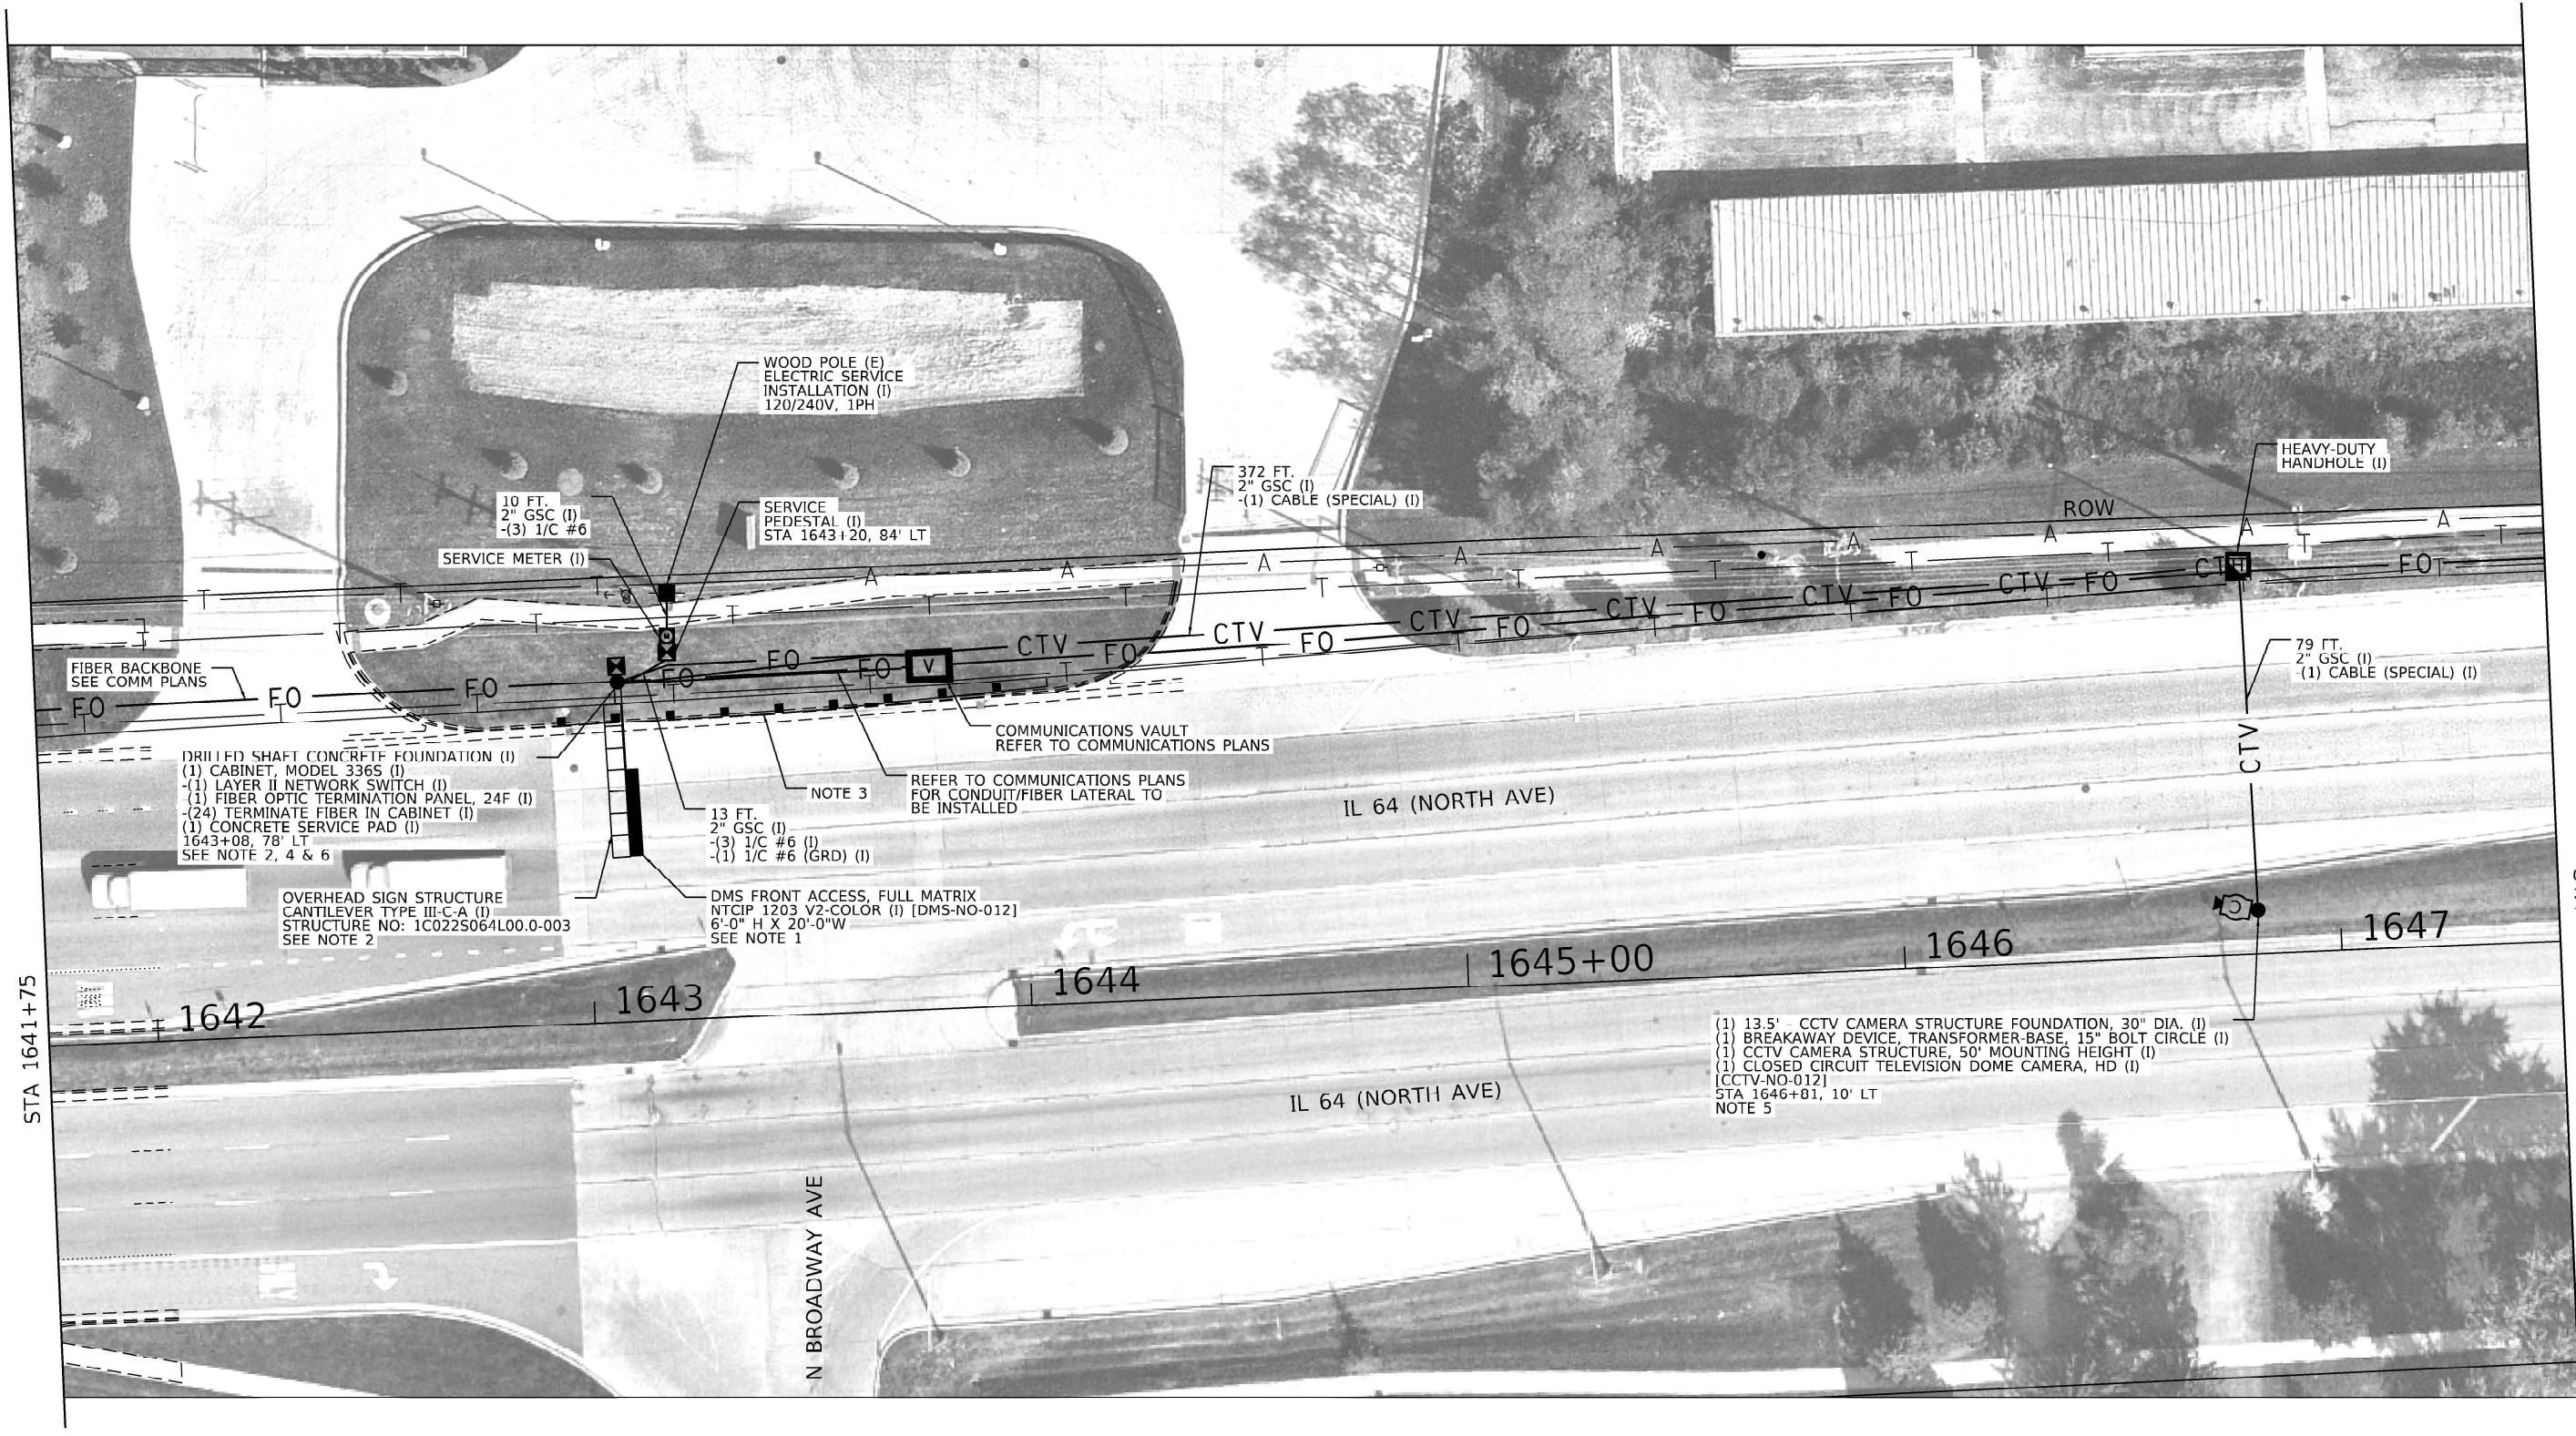 

- NOTES:
1. DMS SIZE IS NOMINAL. DIMENSIONS MAY VARY BY MANUFACTURER.
 2. SEE CANTILEVER SIGN STRUCTURE PLANS FOR FURTHER DETAIL.
 3. SEE CIVIL SITE PLAN FOR GUARDRAIL DETAILS.
 4. REFER TO COMMUNICATIONS PLANS FOR FIBER TERMINATION.
 5. BREAKAWAY COUPLING (PER ARTICLE 838 OF THE STANDARD SPECIFICATIONS) MAY BE USED IN LIEU OF BREAKAWAY DEVICE, TRANSFORMER-BASE, 15" BOLT CIRCLE SUBJECT TO APPROVAL OF THE ENGINEER.
 6. PRIOR TO CONSTRUCTING DMS FOUNDATION, CONTRACTOR TO VERIFY THE LOCATION OF THE FOUNDATION AND CANTILEVER SIGN STRUCTURE MEET THE MINIMUM GUARDRAIL OFFSET REQUIREMENTS.



MODEL: Default
FILE: 1641+75.dwg
PROJECT: 1641+75.dwg
SHEET: 1641+75.dwg
DATE: 1/24/2025
DRAWN: JNR
CHECKED: REL
DATE: 1/24/2025

TranSmart
100 S. Wacker Drive Suite 400
Chicago, Illinois 60606


USER NAME = dmeier	DESIGNED - DJM	REVISED -
	DRAWN - JNR	REVISED -
PLOT SCALE = 40.0000' / in.	CHECKED - REL	REVISED -
PLOT DATE = 1/24/2025	DATE -	REVISED -

STATE OF ILLINOIS
DEPARTMENT OF TRANSPORTATION


SITE INSTALLATION PLANS (DMS/CCTV, TIE-IN)
DMS LOCATION #2

SCALE: 1" = 20' SHEET 1 OF 3 SHEETS STA. 1641+75 TO STA. 1647+50

F.A.P. RTE.	SECTION	COUNTY	TOTAL SHEETS	SHEET NO.
307	2020-263-SUR.SW&TS	DUPAGE	529	483
CONTRACT NO. 62N33				
ILLINOIS FED. AID PROJECT				

 


STA 1797+25

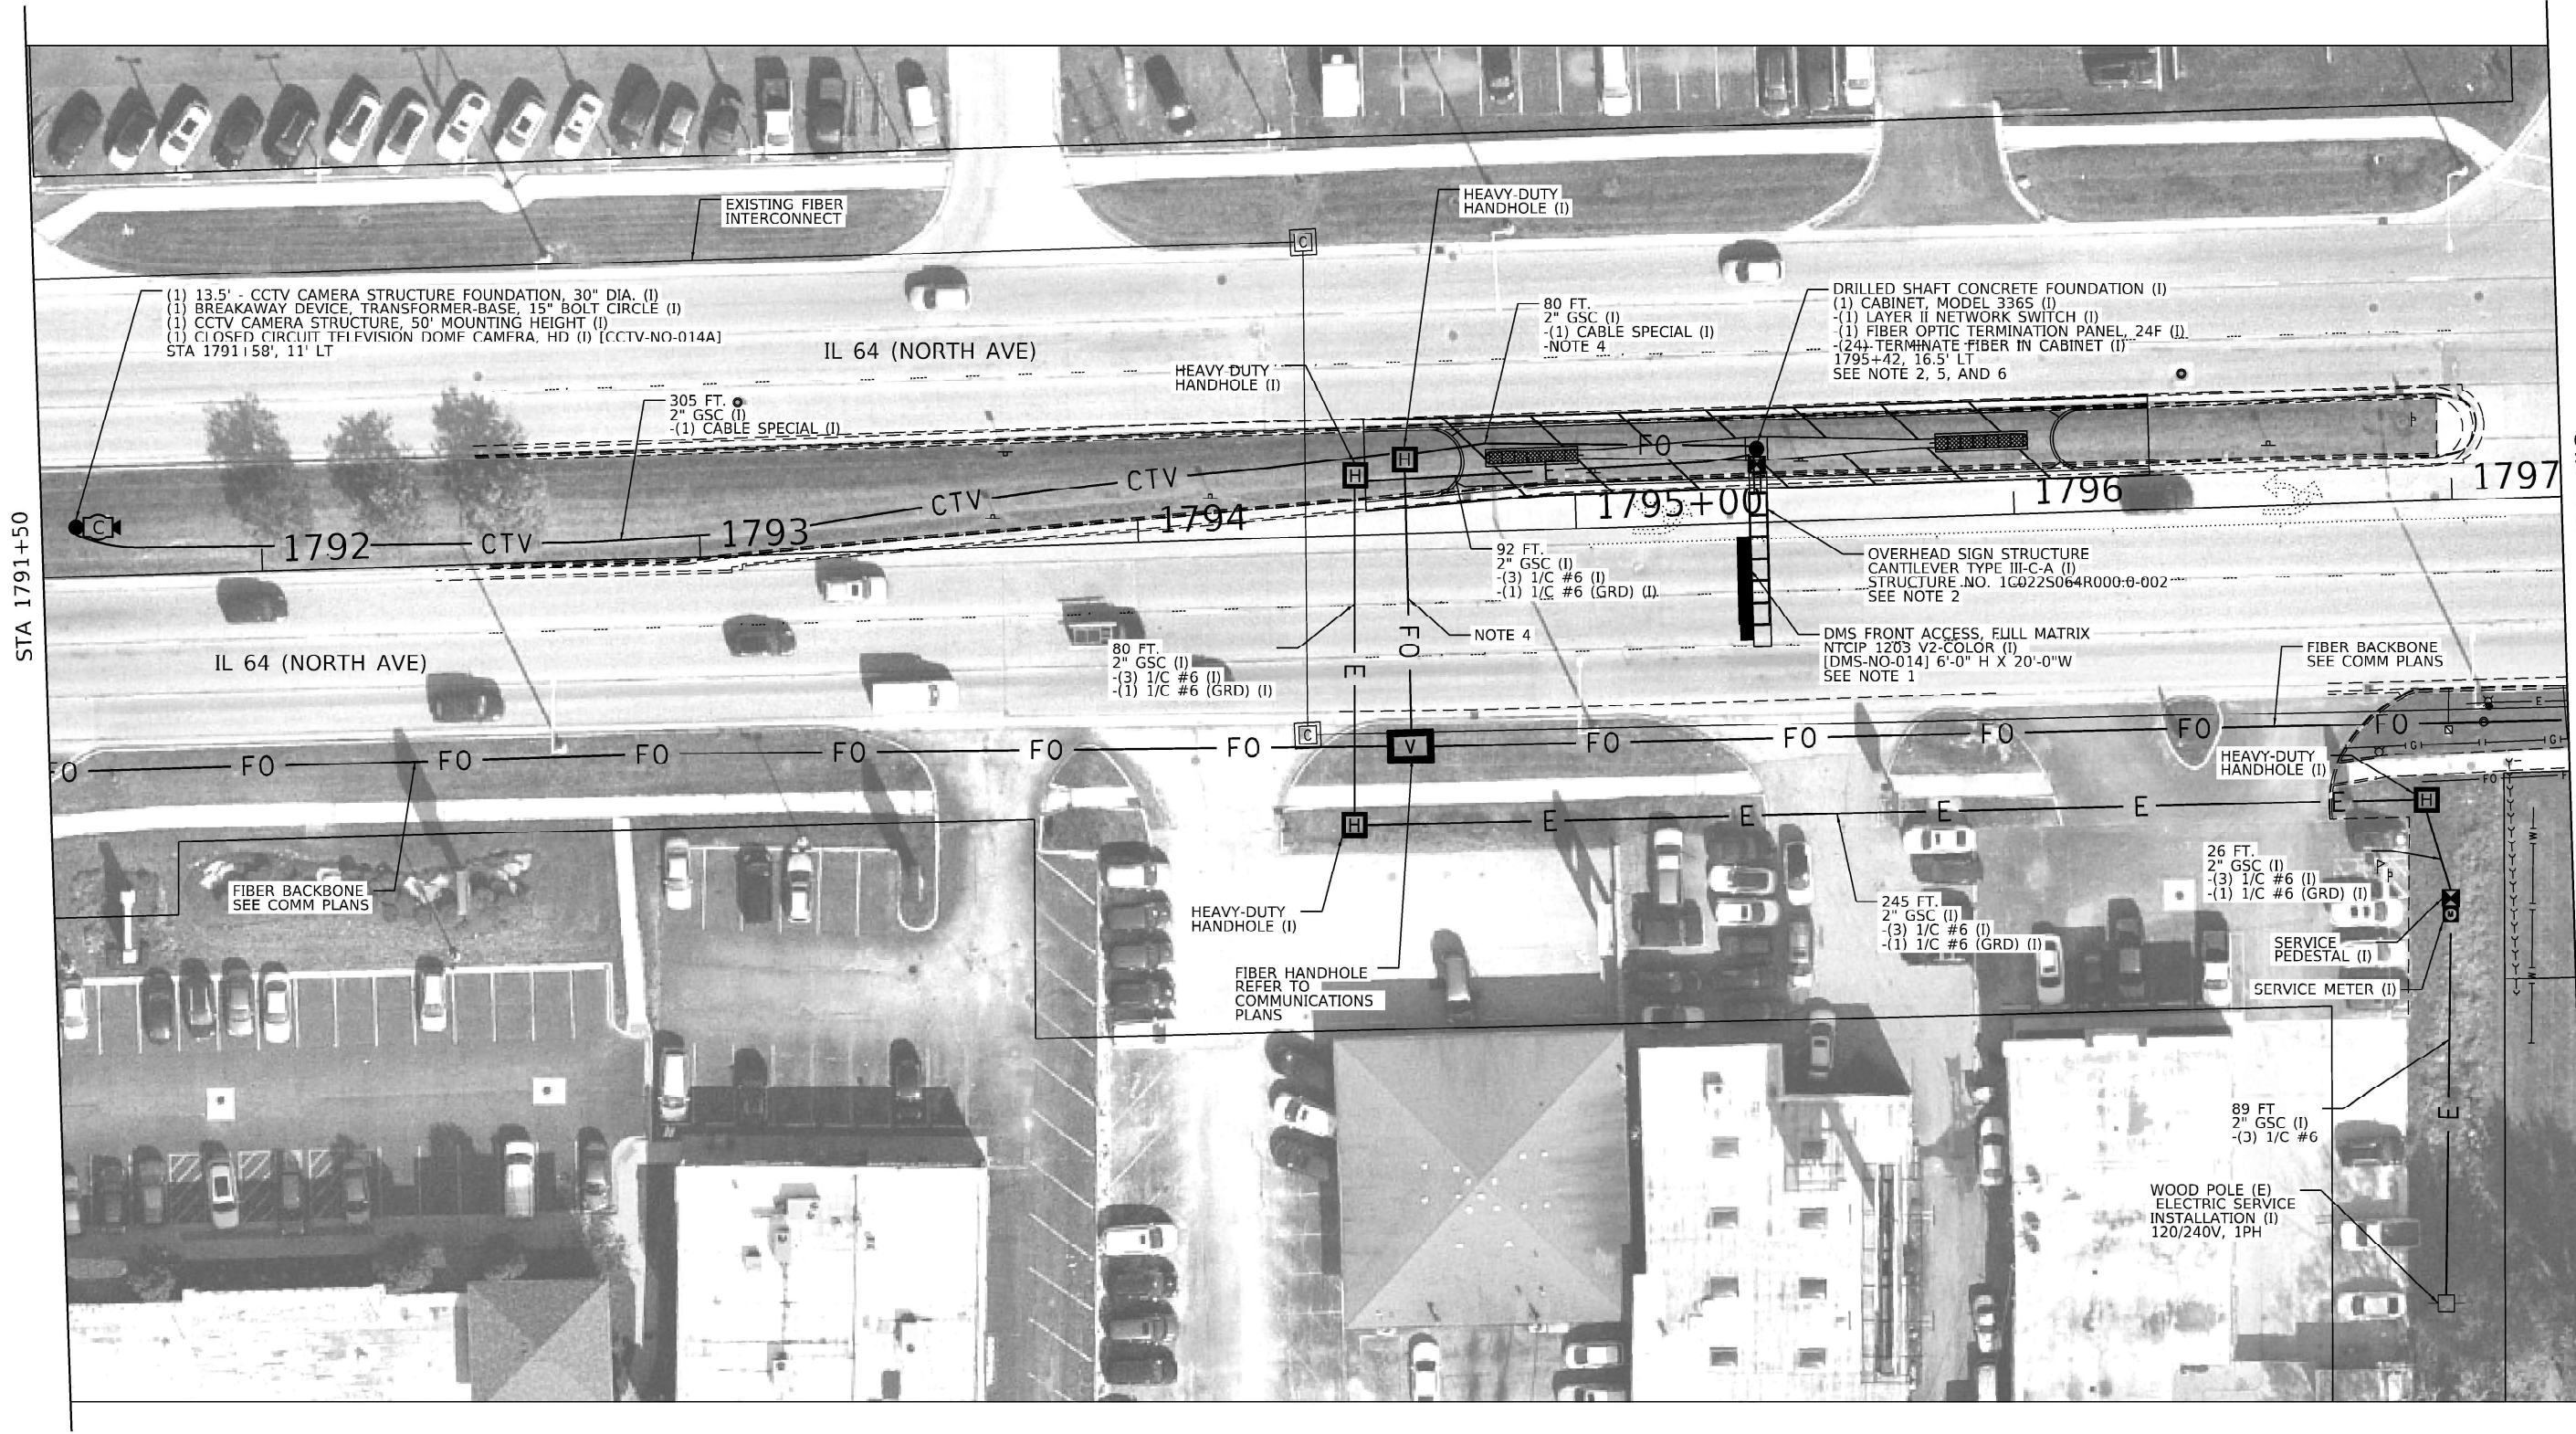

NOTES:

 1. DMS SIZE IS NOMINAL. DIMENSIONS VARY BY MANUFACTURER.
2. SEE CANTILEVER SIGN STRUCTURE PLANS FOR FURTHER DETAIL.
3. SEE CIVIL SITE PLANS FOR FURTHER MEDIAN REMOVE/BARRIER INSTALLATION DETAILS.
4. REFER TO COMMUNICATIONS PLANS FOR FIBER LATERAL TO BE INSTALLED.
5. REFER TO COMMUNICATIONS PLANS FOR FIBER TERMINATIONS.
6. BREAKAWAY COUPLING (PER ARTICLE 838 OF THE STANDARD SPECIFICATIONS) MAY BE USED IN LIEU OF BREAKAWAY DEVICE, TRANSFORMER-BASE, 15\"/>



TranSmart
100 S. Wacker Drive Suite 400
Chicago, Illinois 60606


USER NAME = dmeier	DESIGNED - DJM	REVISED -
	DRAWN - JNR	REVISED -
PLOT SCALE = 40.0000' / in.	CHECKED - REL	REVISED -
PLOT DATE = 1/24/2025	DATE -	REVISED -

STATE OF ILLINOIS
DEPARTMENT OF TRANSPORTATION


SITE INSTALLATION PLANS (DMS/CCTV, TIE-IN)
DMS LOCATION #3

SCALE: 1" = 20' SHEET 2 OF 3 SHEETS STA. 1791+50 TO STA. 1797+25


F.A.P. RTE.	SECTION	COUNTY	TOTAL SHEETS	SHEET NO.
307	2020-263-SUR.SW&TS	DUPAGE	529	484
CONTRACT NO. 62N33				
ILLINOIS FED. AID PROJECT				

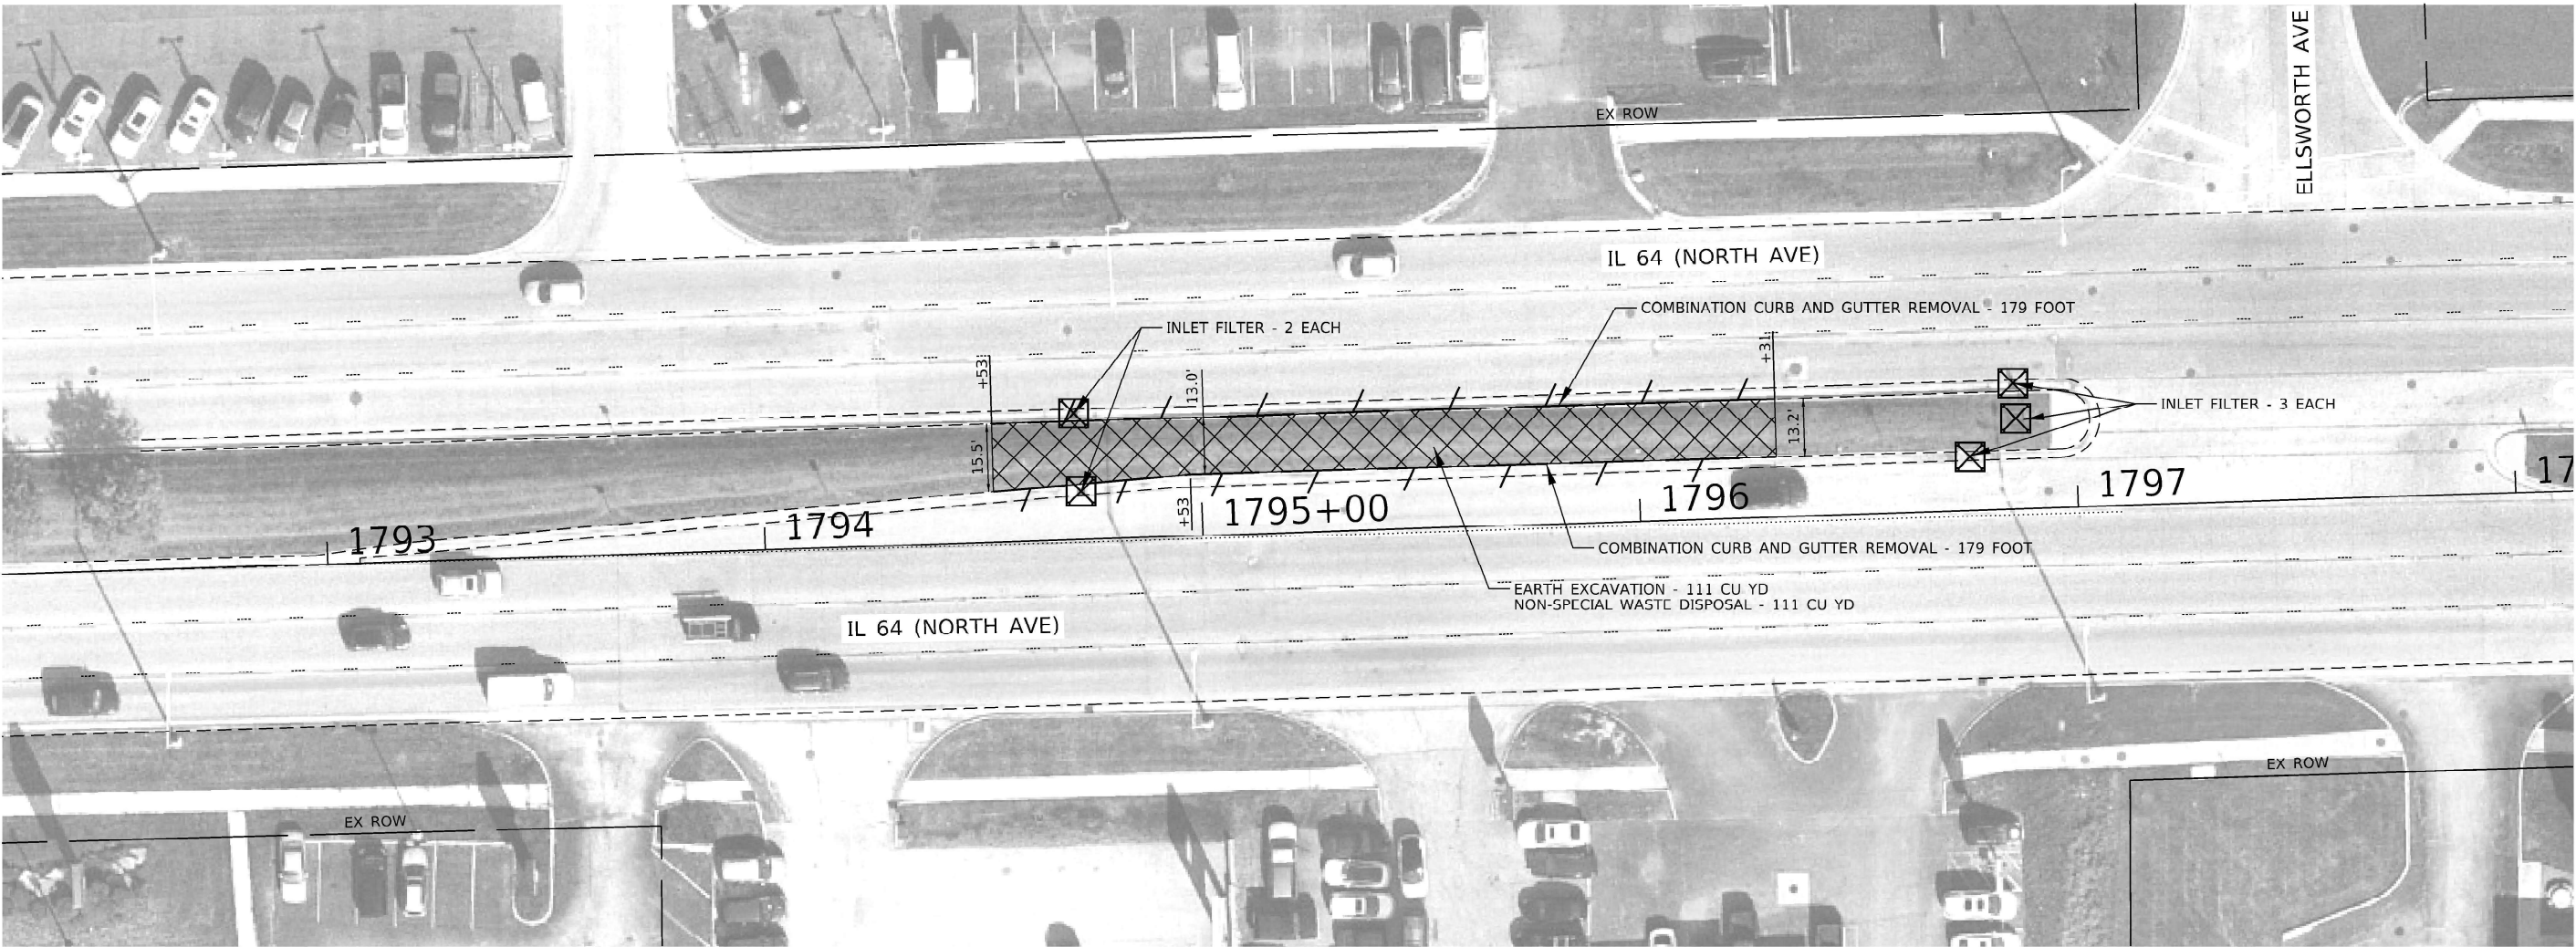

LEGEND

 -  LINEAR REMOVAL ITEMS
-  EARTH EXCAVATION
NON-SPECIAL WASTE DISPOSAL
-  INLET FILTER

- NOTES:**
1. THE CONTRACTOR SHALL MAINTAIN ALL EXISTING DRAINAGE PATTERNS DURING THE DURATION OF CONSTRUCTION ACTIVITIES. ANY TEMPORARY DRAINAGE REQUIRED WILL NOT BE PAID FOR SEPARATELY, BUT SHALL BE CONSIDERED INCIDENTAL TO THE PROJECT.
 2. EROSION CONTROL EFFORTS SHALL BE INSTALLED PRIOR TO CONSTRUCTION AND SHALL BE MAINTAINED THROUGHOUT.
 3. THE CONTRACTOR SHALL USE CARE IN REMOVING OR EXCAVATING NEAR ALL EXISTING ITEMS WHICH WILL REMAIN. ANY DAMAGE DONE TO EXISTING ITEMS BY THE CONTRACTOR SHALL BE REPAIRED AT THE CONTRACTOR'S EXPENSE.

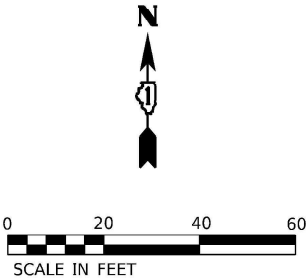

MODEL: Default
FILE: I:\Bentley\p1\h-pw-bentley.com-bp-pw-01\Documents\01 Active Projects\WW-GIS-168953\100 - IL 64\Phase 1\12 Design\CA\Plan Sheets\Communications\West Corridor\108-21-sht-rem01.dwg





USER NAME =	DESIGNED - PWF	REVISED -
	DRAWN - PWF	REVISED -
PLOT SCALE =	CHECKED - KJC	REVISED -
PLOT DATE =	DATE -	REVISED -

STATE OF ILLINOIS
DEPARTMENT OF TRANSPORTATION

SITE REMOVAL PLAN			
IL 64 (NORTH AVE) SMART CORRIDOR			
SCALE: 1" = 20'	SHEET 1	OF 1 SHEETS	STA. 1792+50.00 TO STA. 1798+00.00

F.A.P. RTE.	SECTION	COUNTY	TOTAL SHEETS	SHEET NO.
307	2020-263-SUR.SW&TS	DUPAGE	529	485
				CONTRACT NO. 62N33
ILLINOIS FED. AID PROJECT				

Model: Default
FILE NAME: p:\h-pw-bentley.com\h-pw-01\Documents\01 Active Projects\MM\GIS-160953\100 - IL 64\Phase 1\12 Design\CA\Plan Sheets\Communications\West Corridor\108121-sh-cv01.kit.dgn

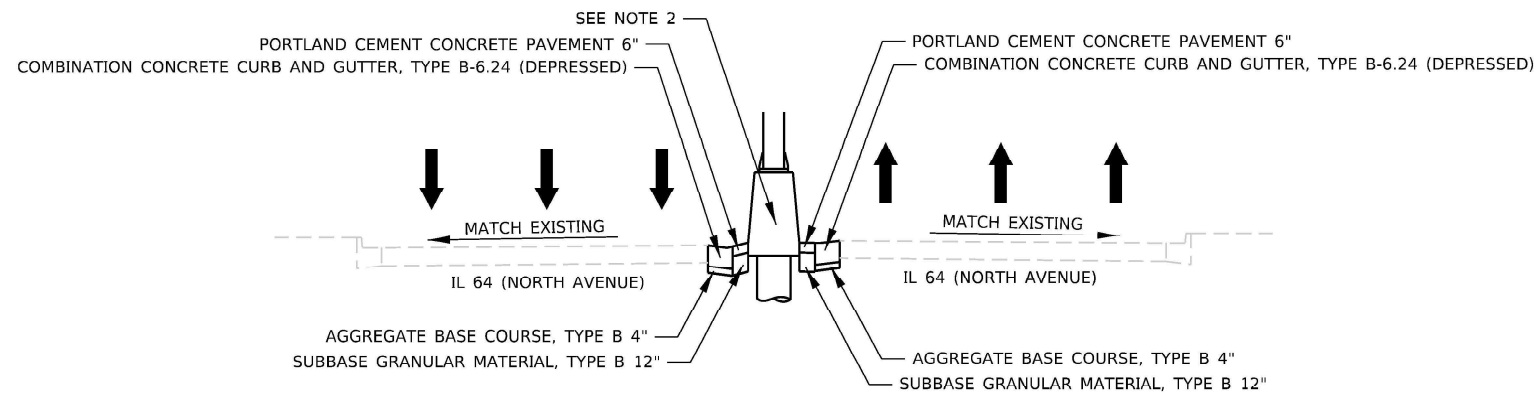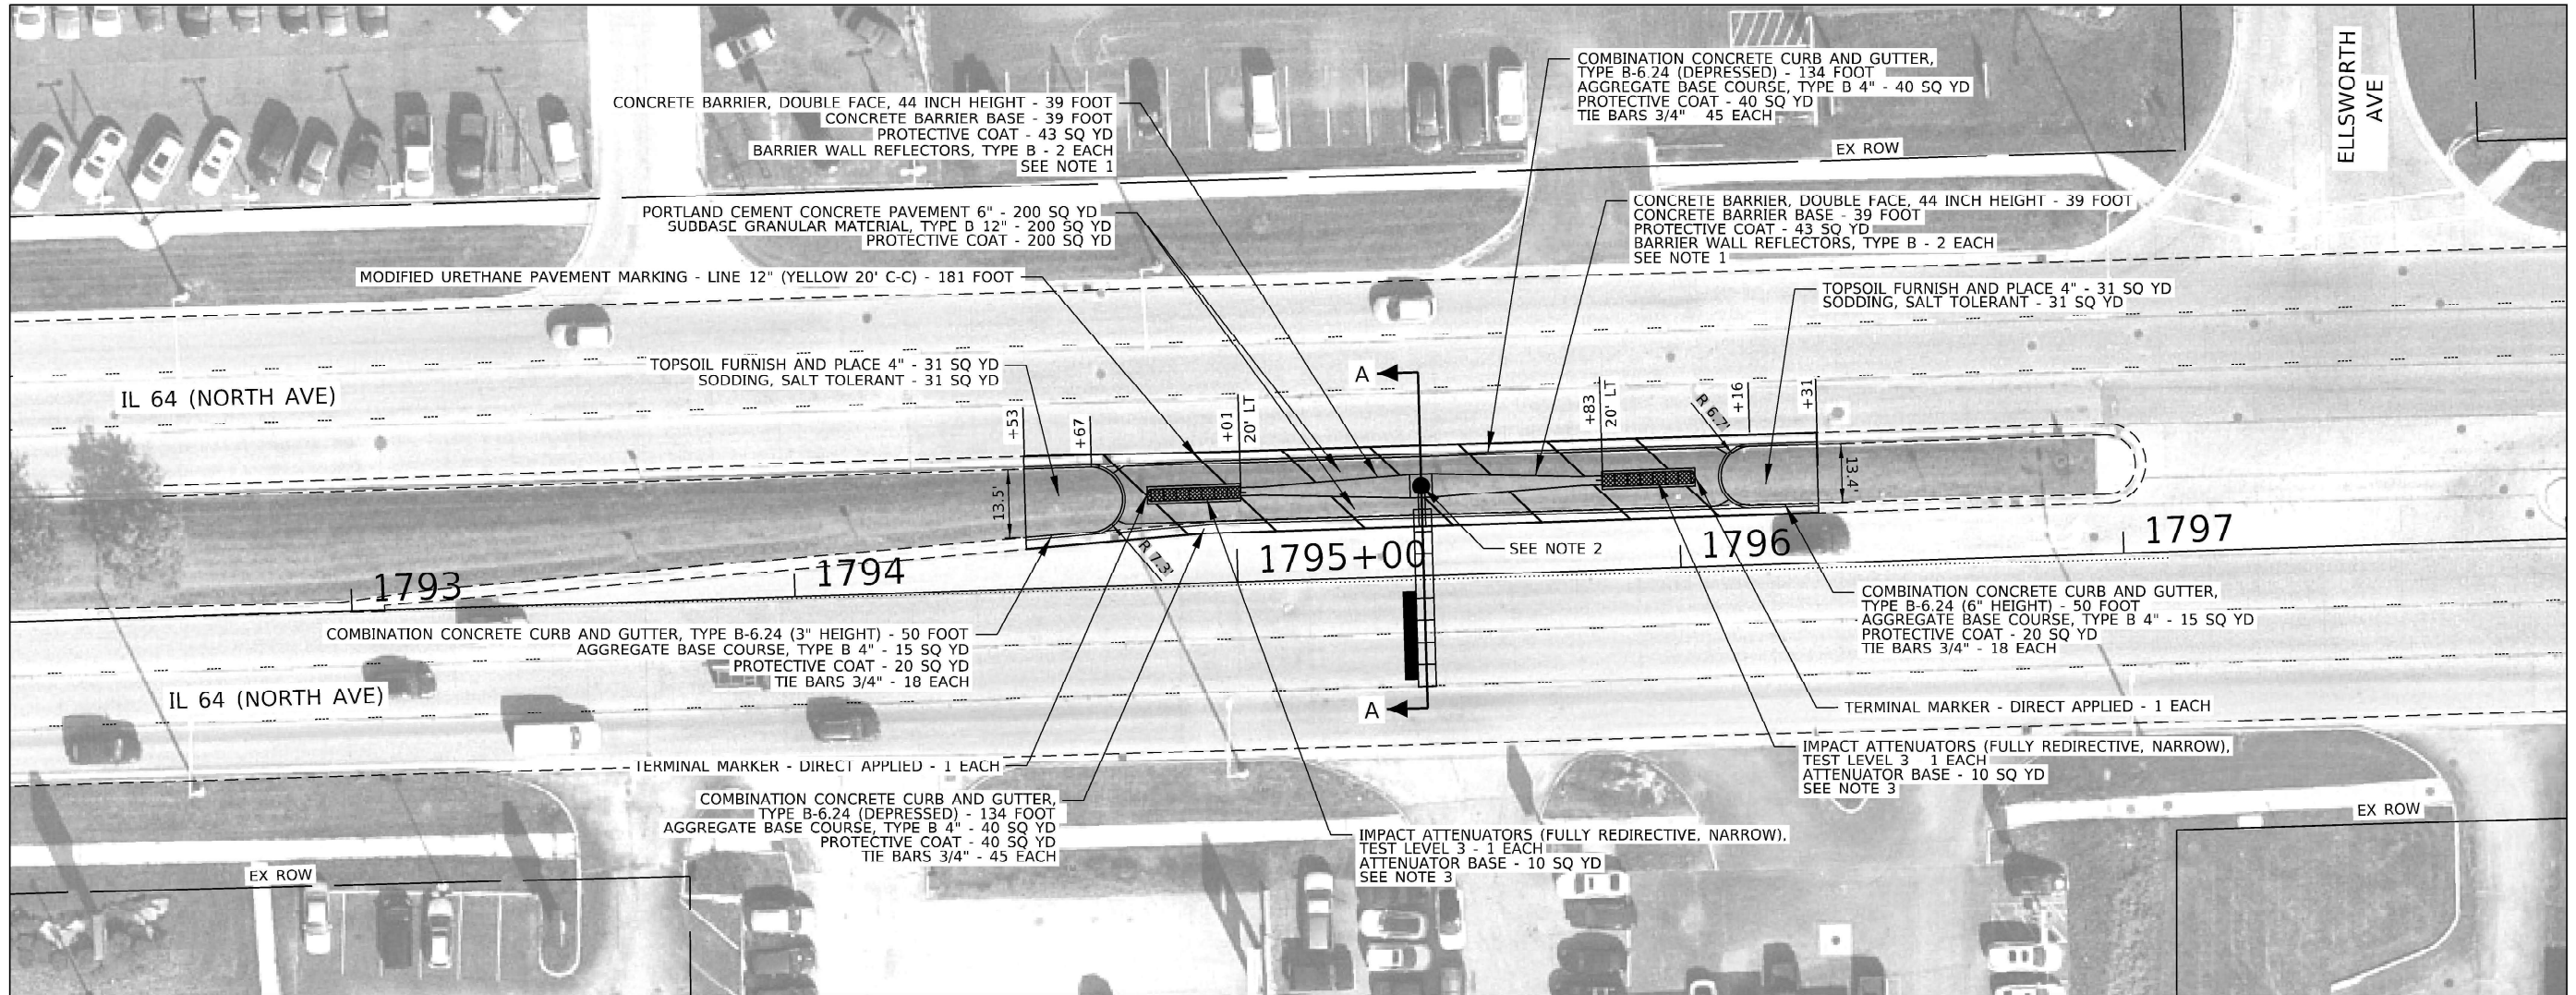

NOTES:

- DOUBLE FACE BARRIER WALL TRANSITION TO BE PAID FOR AS CONCRETE BARRIER, DOUBLE FACE, 44 INCH HEIGHT.
- SEE ITS AND STRUCTURAL PLANS FOR DESIGN AND INSTALLATION OF DMS SIGN TRUSS SIGN AND FOUNDATION.
- IMPACT ATTENUATOR SHALL BE FROM IDOT'S APPROVED QUALIFIED PRODUCT LIST AND MEET MASH TEST LEVEL 3 FOR 62 MPH.

LEGEND



TOPSOIL FURNISH AND PLACE 4"
SODDING, SALT TOLERANT

Kimley-Horn

© 2023 KIMLEY-HORN AND ASSOCIATES, INC.
2005 WILSON DRIVE, SUITE 200
WARRENVILLE, IL 60088
PHONE: 815-487-5500
WWW.KIMLEY-HORN.COM

USER NAME =
DRAWN =
PLOT SCALE =
PLOT DATE =

DESIGNED -
DRAWN -
CHECKED -
DATE -



REVISED -
REVISED -
REVISED -
REVISED -

STATE OF ILLINOIS
DEPARTMENT OF TRANSPORTATION

SITE PLAN
IL 64 (NORTH AVE) SMART CORRIDOR

SCALE: 1" = 20' SHEET 1 OF 1 SHEETS STA. 1792+50.00 TO STA. 1797+50.00

F.A.P. RTE.	SECTION	COUNTY	TOTAL SHEETS	SHEET NO.
307	2020-263-SUR.SW&TS	DUPAGE	529	486
CONTRACT NO. 62N33				
ILLINOIS FED. AID PROJECT				

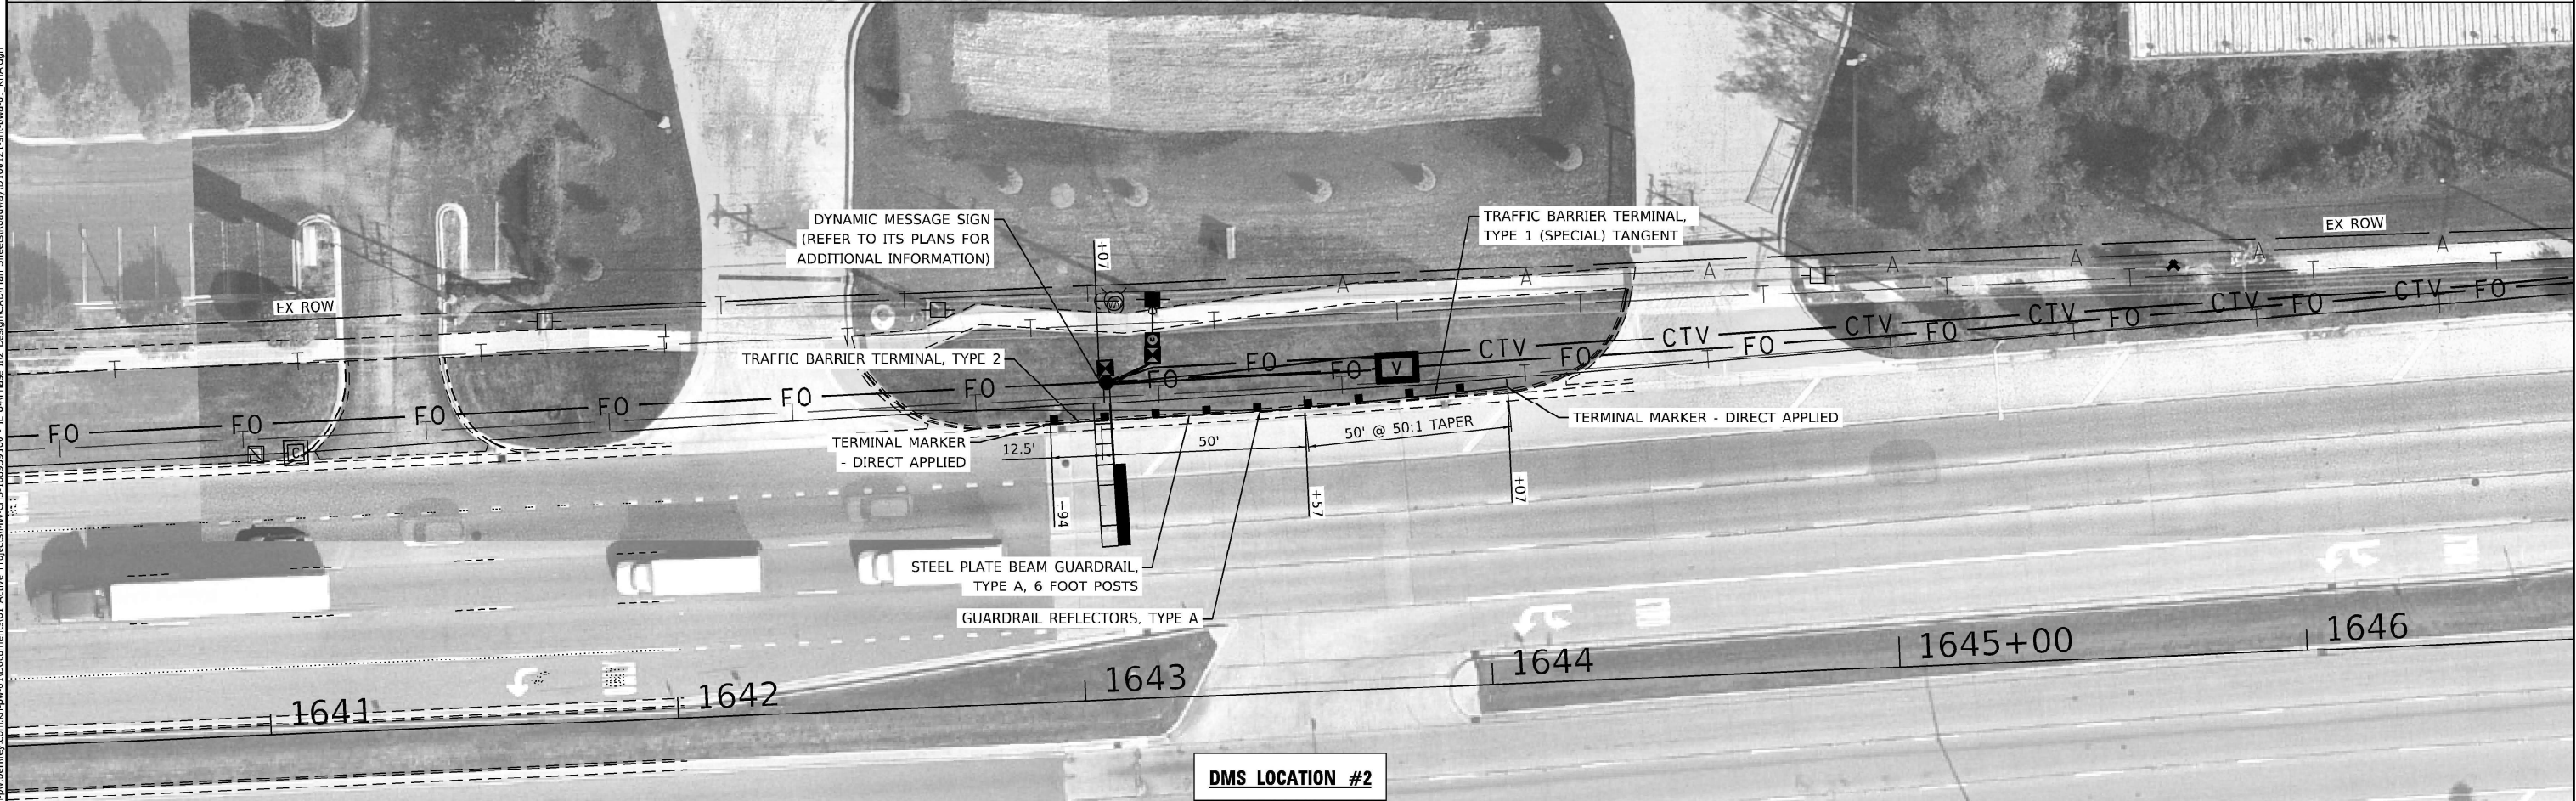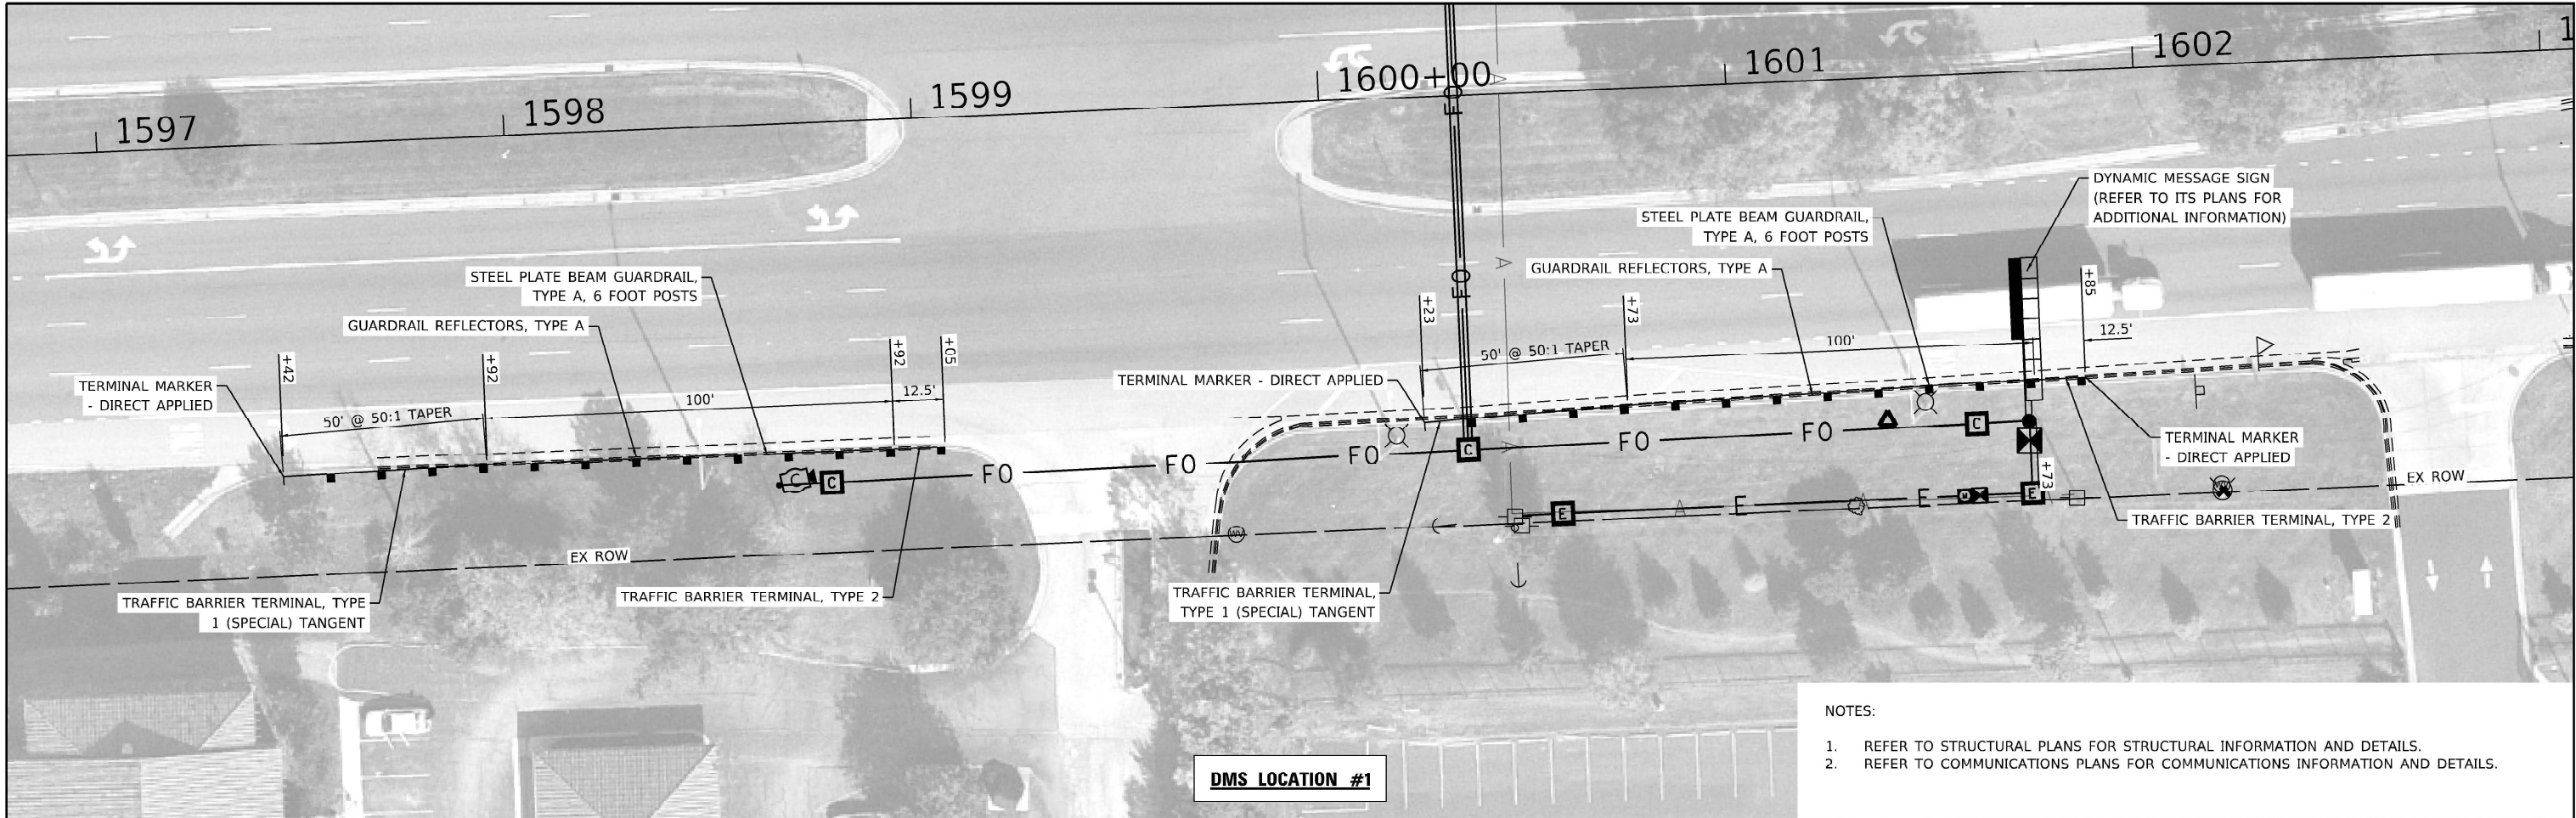

MODEL: Default
FILE: D:\Bentley\proj\hwy-aw-bentley.com\hwy-aw\01\Documents\01 Active Projects\MM\GIS-160953\100 - IL 64\Phase 1112 Design\CACT\Plan Sheets\Roadway\1108171-sh-bwa-01_KHA.dgn

KimleyHorn
© 2020 KIMLEY HORN AND ASSOCIATES, P.A.
4000 WILSON DRIVE, SUITE 400
WARRENVILLE, IL 60089
PHONE: 630-467-5500
WWW.KIMLEYHORN.COM




USER NAME =	DESIGNED -	REVISED -
	DRAWN -	REVISED -
PLOT SCALE =	CHECKED -	REVISED -
PLOT DATE =	DATE -	REVISED -

STATE OF ILLINOIS
DEPARTMENT OF TRANSPORTATION

SITE INSTALLATION PLANS (DMS/CCTV, TIE-IN)
DMS LOCATION #1 AND #2



SCALE: SHEET OF SHEETS STA. TO STA.

F.A.P. RTE.	SECTION	COUNTY	TOTAL SHEETS	SHEET NO.
307	2020-263-SUR.SW&TS	DUPAGE	529	487
CONTRACT NO. 62N33				
ILLINOIS FED. AID PROJECT				

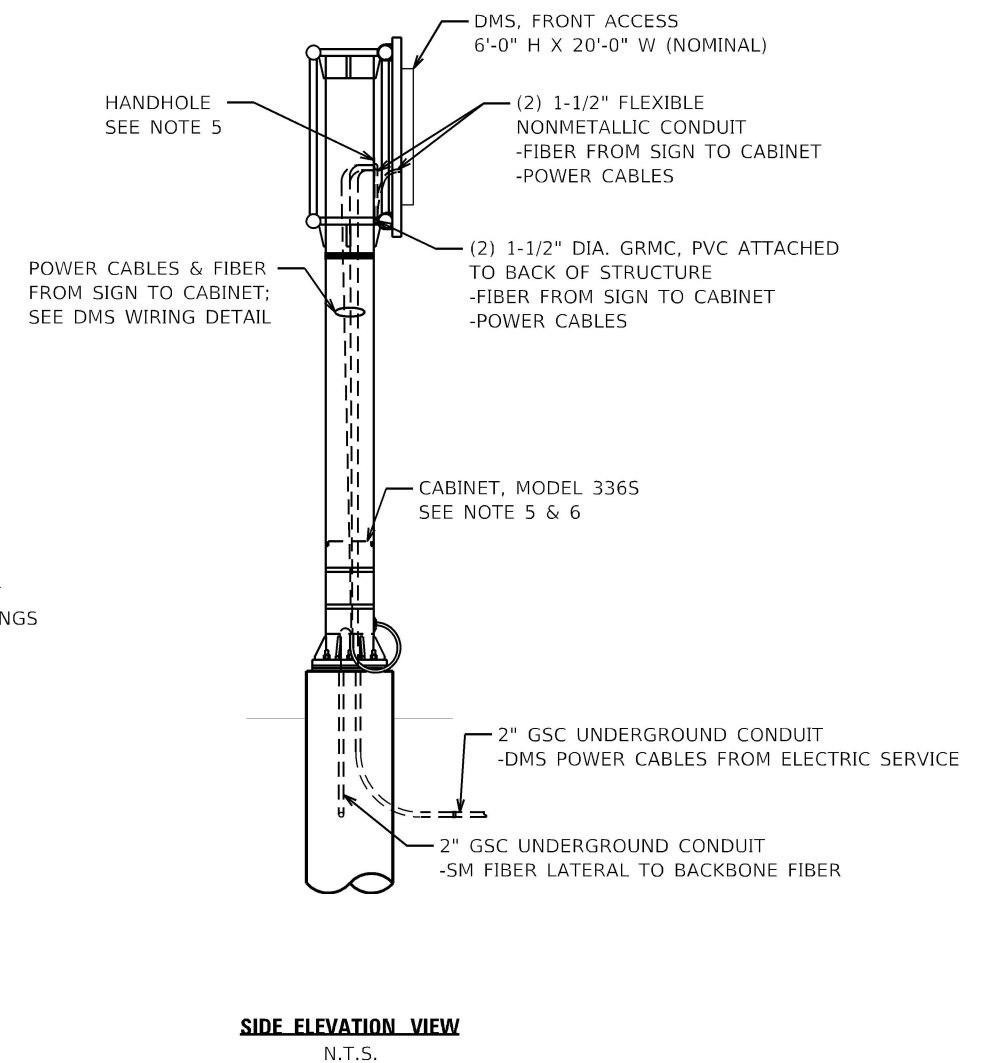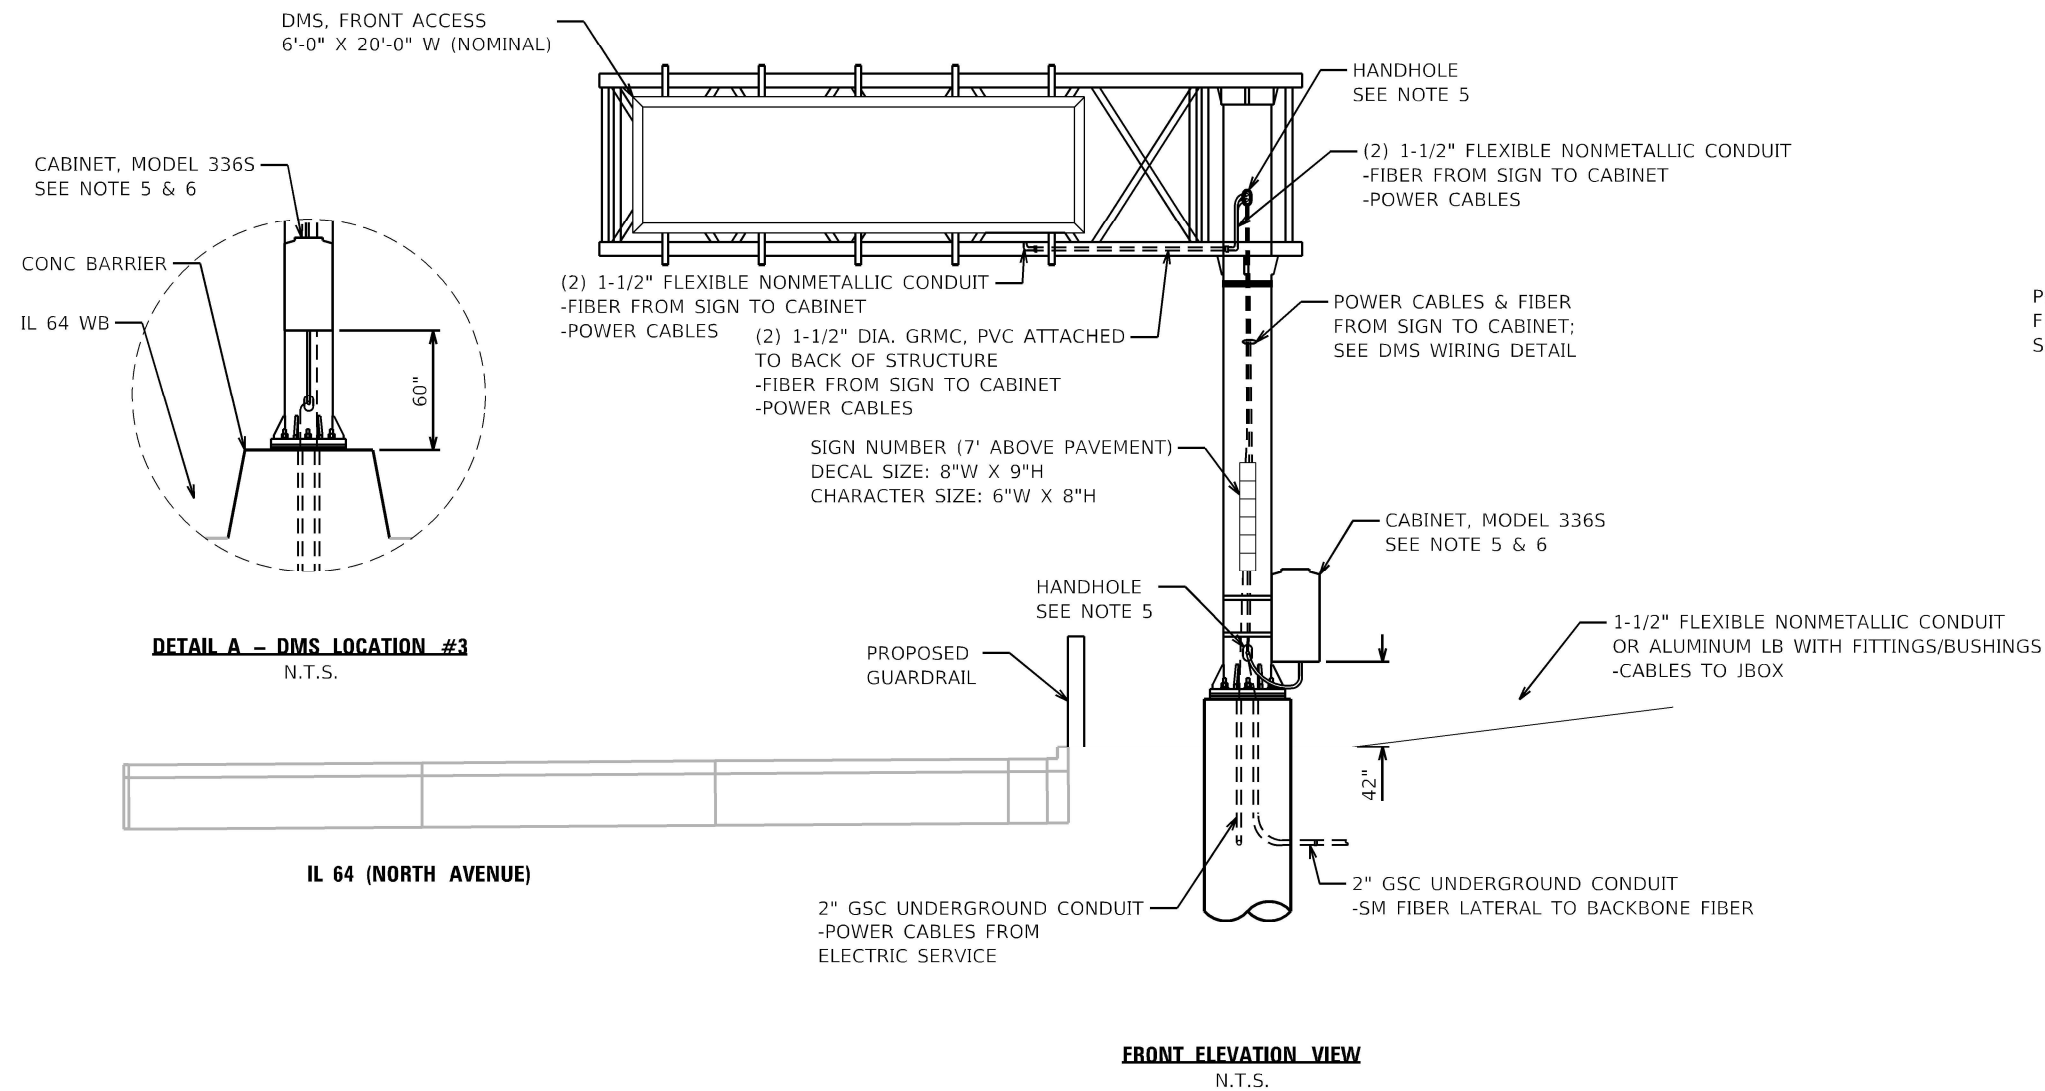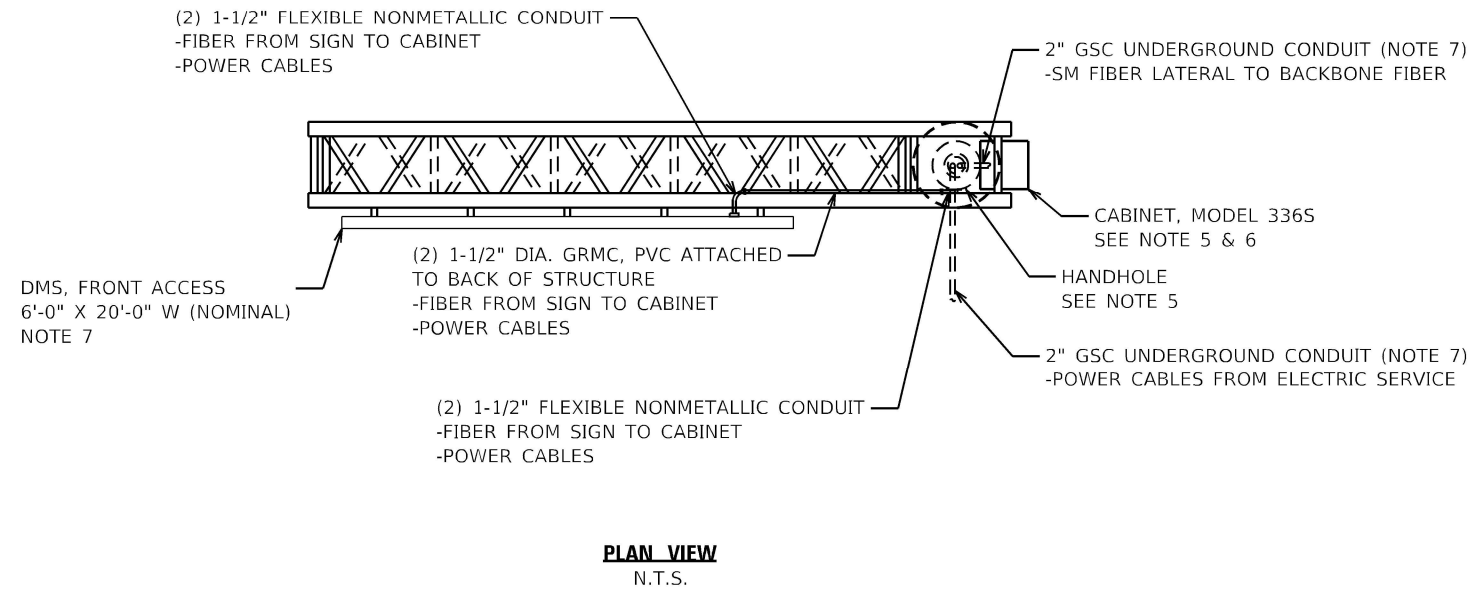


- ## NOTES


1. ALL CONDUIT BENDS SHALL HAVE A MINIMUM RADIUS OF 12 INCHES. CONTRACTOR SHALL INSTALL SM FIBER LATERAL SO AS NOT TO VIOLATE MANUFACTURER'S SPECIFIED BENDING RADIUS.
2. ALL CONDUIT ATTACHED TO STRUCTURE SHALL BE GALVANIZED RIGID METALIC CONDUIT, PVC COATED (GRMC, PVC). CONDUIT SHALL BE SECURED TO THE STRUCTURE WITH PVC COATED CONDUIT CLAMPS SPACED AT A MAXIMUM DISTANCE OF 5'.
3. THE USE OF LIQUID TIGHT FLEXIBLE NONMETALLIC CONDUIT SHALL BE LIMITED TO LOCATIONS WHERE MOVEMENT IS ANTICIPATED AND SHALL NOT EXCEED 5' IN LENGTH.
4. ALL CONDUIT ON STRUCTURE IS INCLUDED UNDER PAY ITEM X0327130 (DMS FRONT ACCESS, FULL MATRIX, NTCIP 1203 V2-COLOR) AND WILL NOT BE PAID FOR SEPARATELY.
5. INSTALL CONDUIT HUB(S) TO ACCEPT 1-1/2" FLEXIBLE NONMETALLIC CONDUIT. THIS WORK IS INCLUDED UNDER PAY ITEM X0327130 (DMS FRONT ACCESS, FULL MATRIX, NTCIP 1203 V2-COLOR) AND WILL NOT BE PAID FOR SEPARATELY.
6. THE CABINET, MODEL 3365 ATTACHED TO THE DMS SIGN STRUCTURE SHALL BE PAID FOR SEPARATELY UNDER PAY ITEM X1400416 (CABINET, MODEL 3365).
7. THIS IS A TYPICAL DETAIL. SITE CONDITIONS WILL VARY. DETERMINE THE ORIENTATION OF THE SIGN, JUNCTION BOX, AND THE CONDUIT APPROACH/ENTRY TO THE FOUNDATION BASED ON SITE SPECIFIC CONDITIONS (REFER TO PLANS).

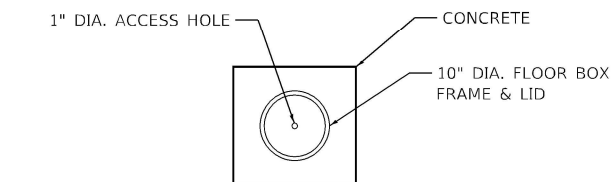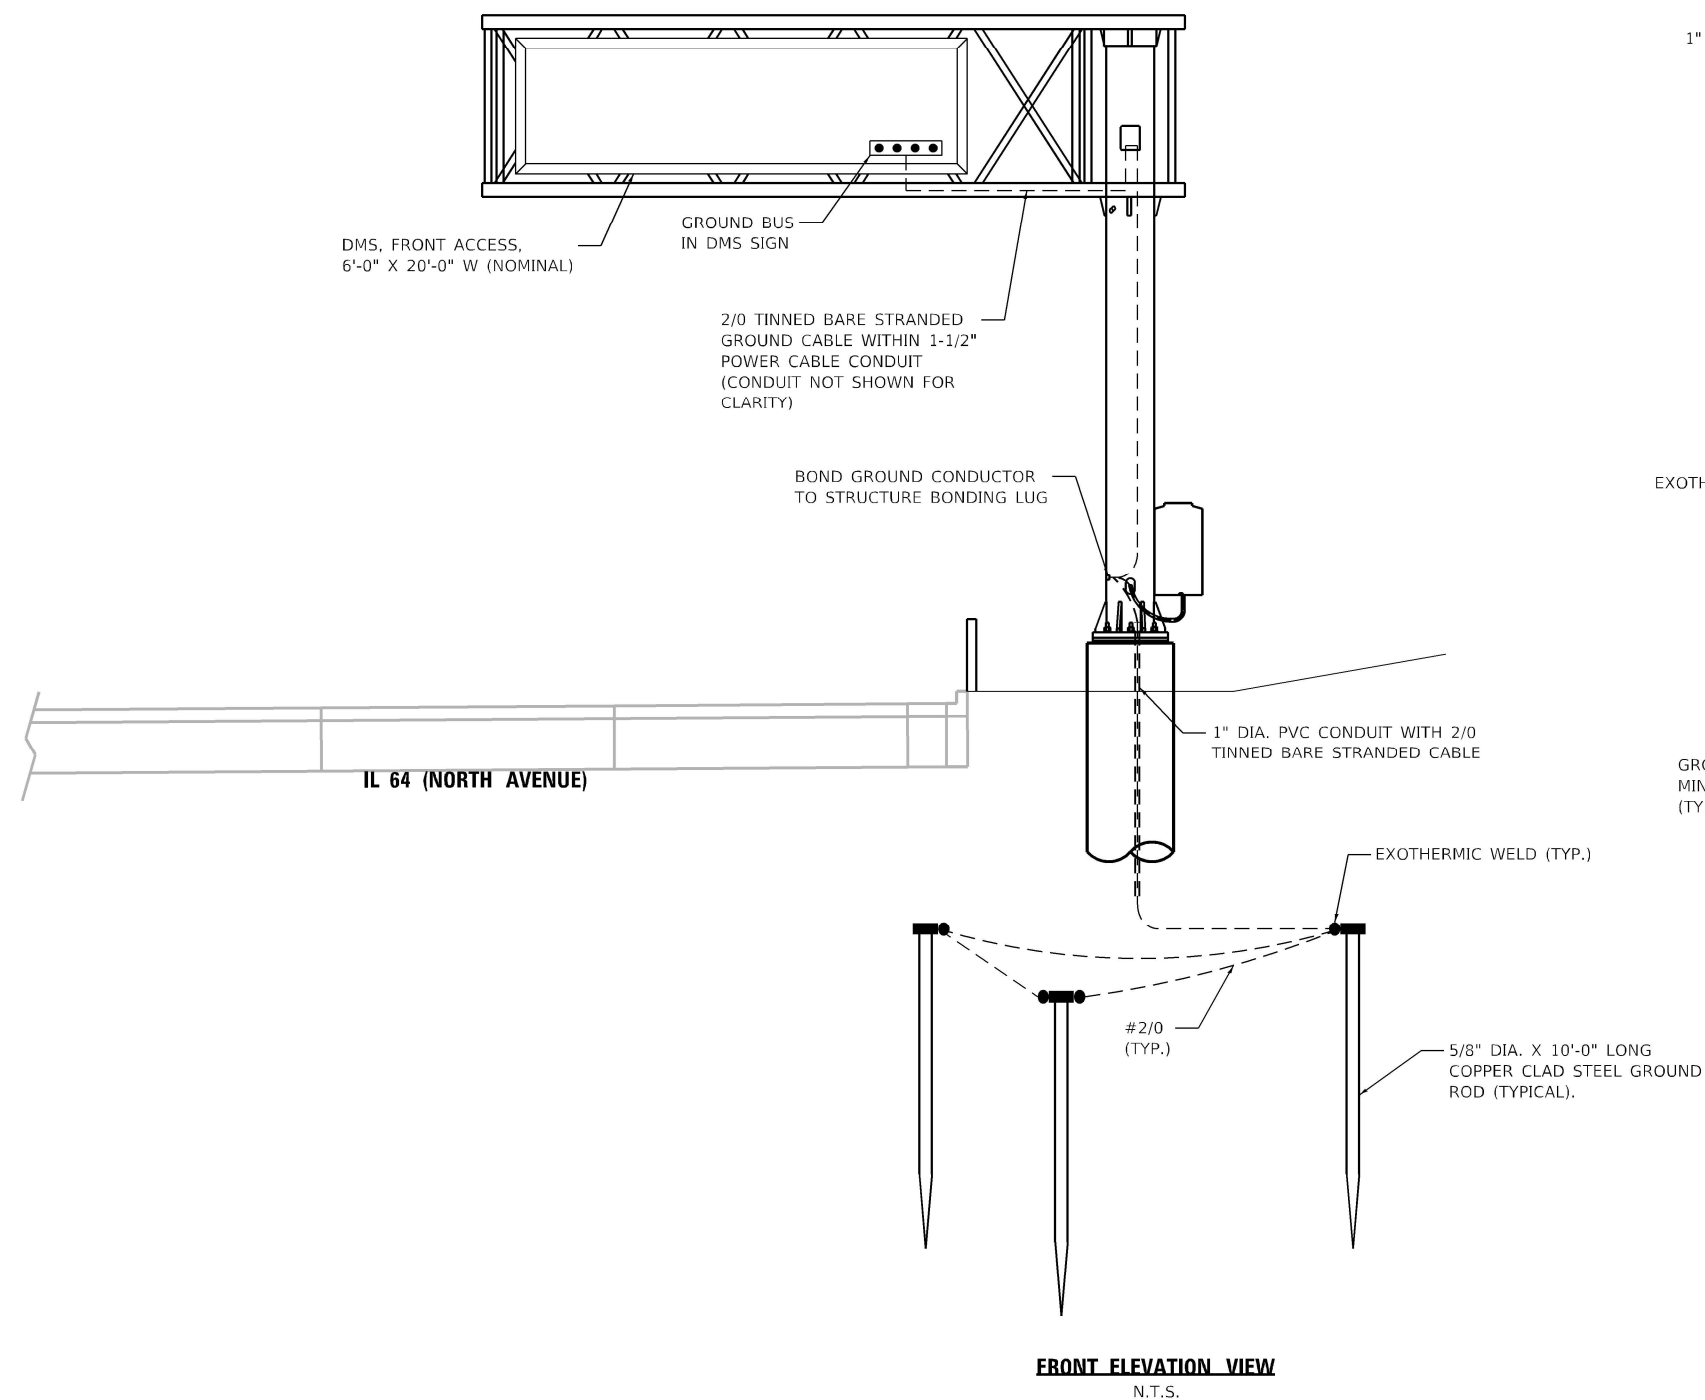

GROUND WELL PLAN DETAIL
N.T.S.

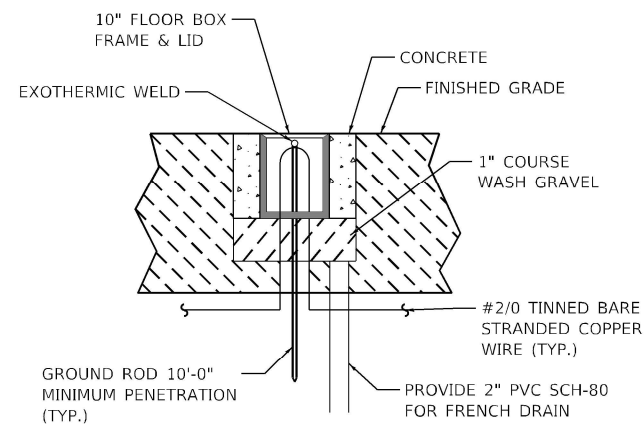


GROUND WELL ELEVATION DETAIL
N.T.S.

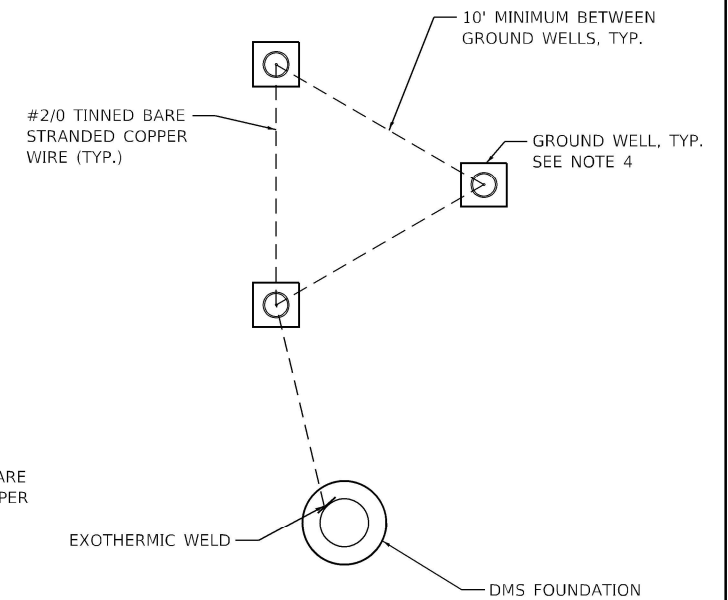

GROUNDING SCHEMATIC
N.T.S.

NOTES:

1. GROUNDING SYSTEM IS INCLUDED UNDER PAY ITEM X0327130 (DMS FRONT ACCESS, FULL MATRIX, NTCIP 1203 V2-COLOR AND WILL NOT BE PAID SEPARATELY.
2. GROUND RODS SHALL BE INSTALLED IN GROUND WELLS AT FINISHED GRADE.
3. AT LEAST AN 8-INCH MINIMUM BENDING RADIUS SHALL BE MAINTAINED ON ALL GROUNDING ELECTRODE CONDUCTORS. THE ANGLE OF ANY BENDING SHALL NOT BE LESS THAN 90 DEGREES.
4. GROUND WELLS SHALL NOT BE PLACED IN PAVED AREAS. FOR DMS LOCATION #2, ALL GROUND WELLS SHALL BE PLACED PAST THE END OF CONCRETE BARRIER/ATTENUATOR SYSTEM.
5. THIS IS A TYPICAL DETAIL. SITE CONDITIONS WILL VARY. DETERMINE THE ORIENTATION OF THE SIGN, AND JUNCTION BOX BASED ON SITE SPECIFIC CONDITIONS (REFER TO PLANS).

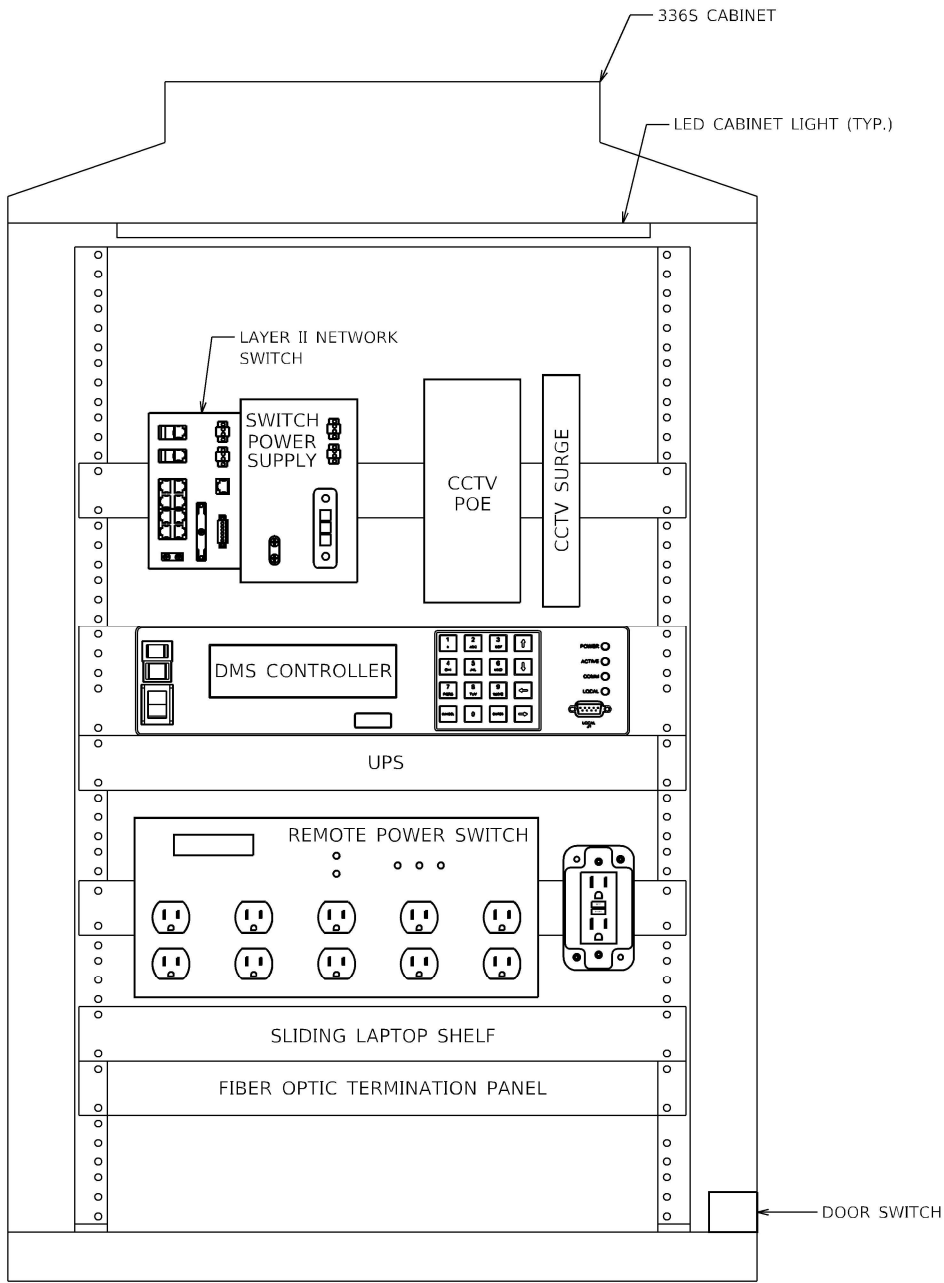

336S DMS CABINET - TYPICAL CABINET LAYOUT
FRONT ELEVATION VIEW

MODEL: Default
FILE: \\bentley.com\kjb\p-w-d\Documents\01_Active Projects\MMW-CUS-168950-100 - IL 64Phase, II\2_Design\CAD\Draw_Sheets\ITSS\slsh-DMS\West_Corridor\00812141r-dmsdetail06_TSM.dgn

TranSmart
100 S. Wacker Drive Suite 400
Chicago, Illinois 60606

USER NAME = dmeier	DESIGNED - DJM	REVISED -
DRAWN - DJM	REVISED -	
PLOT SCALE = 2.0000 ' / in.	CHECKED - REL	REVISED -
PLOT DATE = 1/24/2025	DATE -	REVISED -

STATE OF ILLINOIS
DEPARTMENT OF TRANSPORTATION


DEVICE DETAILS
336S CABINET LAYOUT

SCALE: N.T.S. SHEET 3 OF 6 SHEETS STA. N/A TO STA. N/A


F.A.P. RTE.	SECTION	COUNTY	TOTAL SHEETS	SHEET NO.
307	2020-263-SUR,SW&TS	DUPAGE	529	490
CONTRACT NO. 62N33				
ILLINOIS FED. AID PROJECT				

NOTES:


- SERVICE PADS SHALL BE INSTALLED ON SLOPES EQUAL TO OR LESS THAN 1:3.
- ALL EXPOSED CONCRETE EDGES SHALL HAVE A 1" MINIMUM CHAMFER.
- CONTRACTOR SHALL TAKE PRECAUTIONS TO STABILIZE EXISTING DMS STRUCTURE AND FOUNDATIONS WHILE EXCAVATING SOIL FOR INSTALLATION OF CONCRETE SERVICE PADS.
- COMPACTED SOIL SHALL BE PLACED TO BE LEVEL WITH THE SERVICE PAD. CONTRACTOR MAY USE EXCAVATED SOIL FROM PLACING THE PAD'S AGGREGATE BASE FOR GRADING PURPOSES WITH APPROVAL OF THE ENGINEER.
- SOIL EXCAVATED FOR THE PURPOSE OF MAINTAINING A STABLE WORKING SLOPE WHILE INSTALLING THE SERVICE PAD SHALL BE REPLACED. BACKFILL SHALL BE EARTH WHICH IS FREE FROM DEBRIS, CINDERS, AND ROCKS MEASURING 2" OR GREATER IN DIAMETER. IN THE EVENT THAT EXCAVATED MATERIAL IS UNSUITABLE FOR USE AS BACKFILL, THE CONTRACTOR SHALL USE A CLEAN, NATURAL SAND. THIS SUBSTITUTE BACKFILL SHALL BE INCIDENTAL TO THE SERVICE PAD INSTALLATION AND WILL NOT BE PAID FOR SEPARATELY. ALL BACKFILL MATERIALS SHALL BE COMPACTED TO THE SATISFACTION OF THE ENGINEER.
- THE TOP SURFACE OF SOIL DISTURBED BY EXCAVATION FOR PLACING THE SERVICE PADS SHALL BE SEEDED AND PROTECTED WITH EROSION CONTROL MEASURES.
- SURFACE OF SERVICE PADS SHALL BE BROOM FINISHED.
- THE CONTRACTOR SHALL RETAIN THE SOLE RESPONSIBILITY FOR THE MEANS, METHODS, AND TECHNIQUES OF CONSTRUCTION OF THE PADS AND FOR COMPLIANCE WITH LAWS, REGULATIONS, AND CODES, AND FOR THE SAFETY OF CONSTRUCTION APPLICABLE TO THIS WORK.

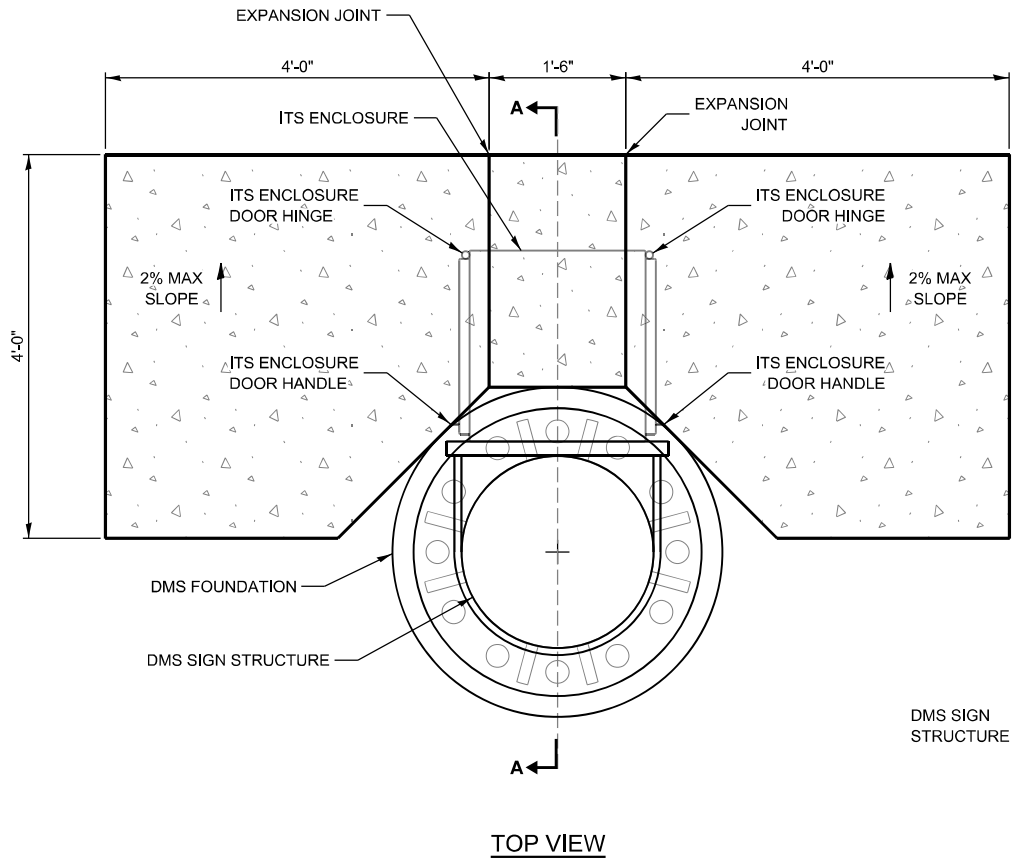

TOP VIEW

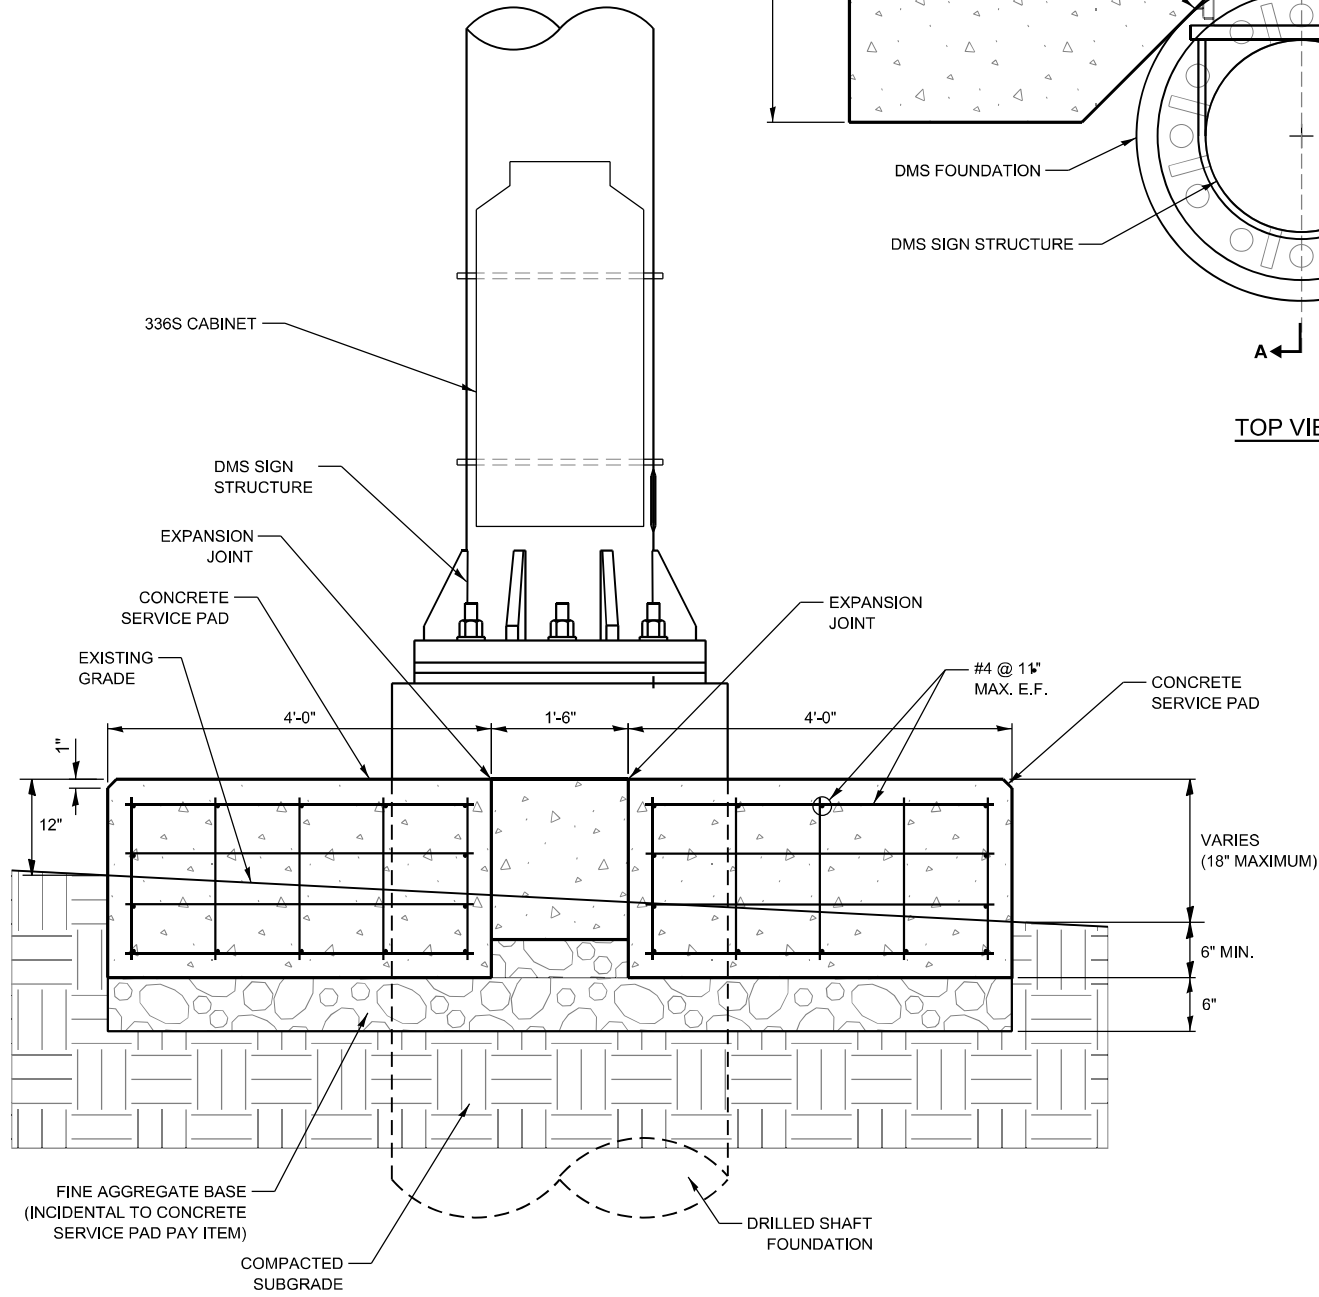

SECTION B-B

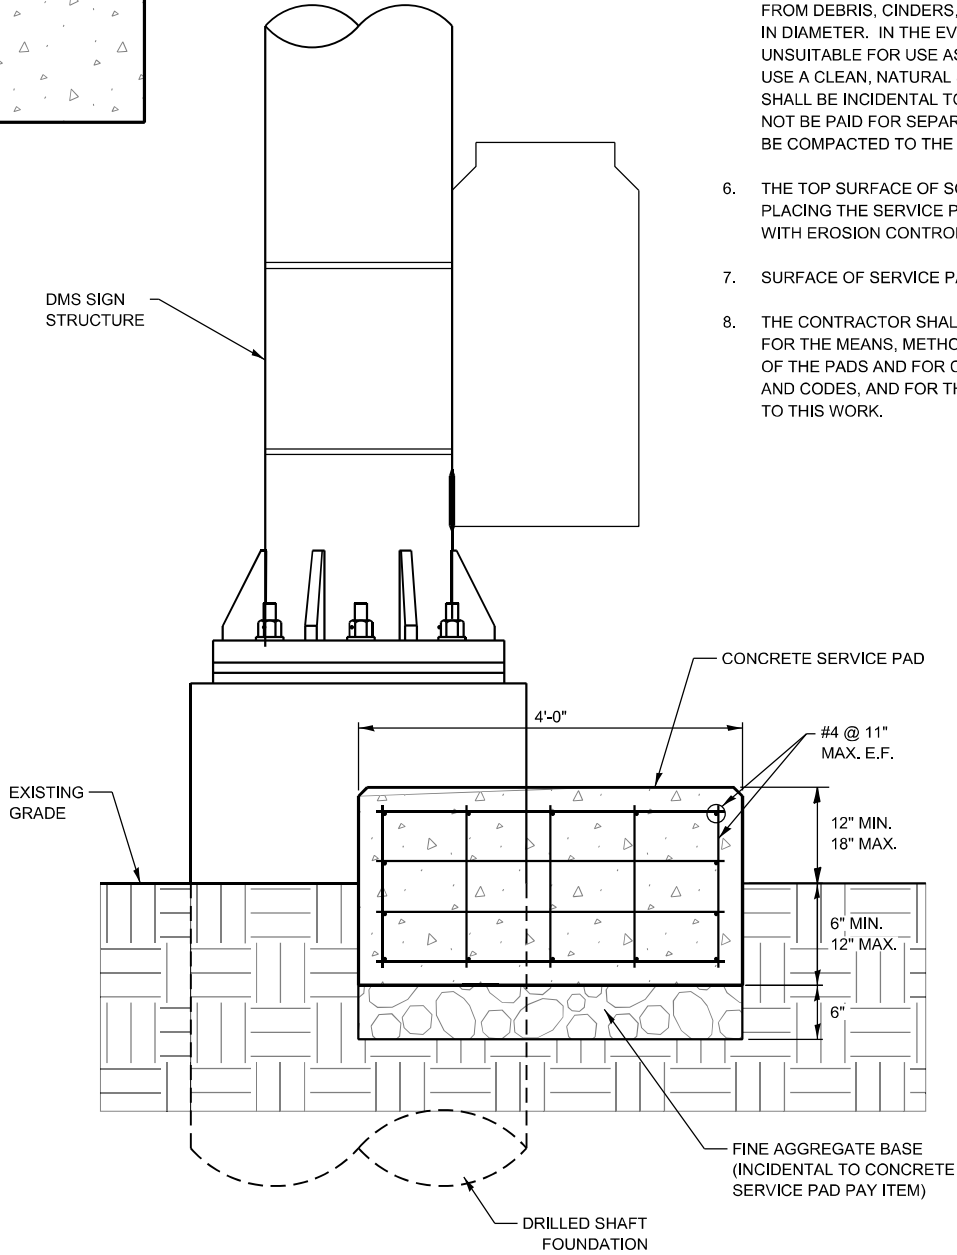


SECTION A-A

MODEL: Default
FILE: Kimley-Horn\pvt-bentley.com\h-pvt-d1\Documents\01 Active Projects\IMW-CHS-180950\00 - IL 64\Phase II\2 Design\CAD\Plan Sheets\Communications\West Corridor\0108121-1-1-1-dms-det-01.kim.dgn


USER NAME =	DESIGNED -	REVISED -
	DRAWN -	REVISED -
PLOT SCALE =	CHECKED -	REVISED -
PLOT DATE =	DATE -	REVISED -

F.A.P. RTE.	SECTION	COUNTY	TOTAL SHEETS	SHEET NO.
307	2020-263-SUR-SW&TS	DUPAGE	529	491
CONTRACT NO. 62N33				
ILLINOIS FED. AID PROJECT				

MODEL: Default
FILE: 307-263-SUR-336S-CABINET.dwg
PROJECT: 307-263-SUR-336S-CABINET.dwg
SHEET: 307-263-SUR-336S-CABINET.dwg
DATE: 1/24/2025
DRAWN: DJM
CHECKED: REL
DESIGNED: DJM
REVISOR: DJM
STATE OF ILLINOIS
DEPARTMENT OF TRANSPORTATION
F.A.P. RTE. SECTION COUNTY TOTAL SHEETS SHEET NO.
307 2020-263-SUR,SW&TS DUPAGE 529 492
CONTRACT NO. 62N33
ILLINOIS FED. AID PROJECT

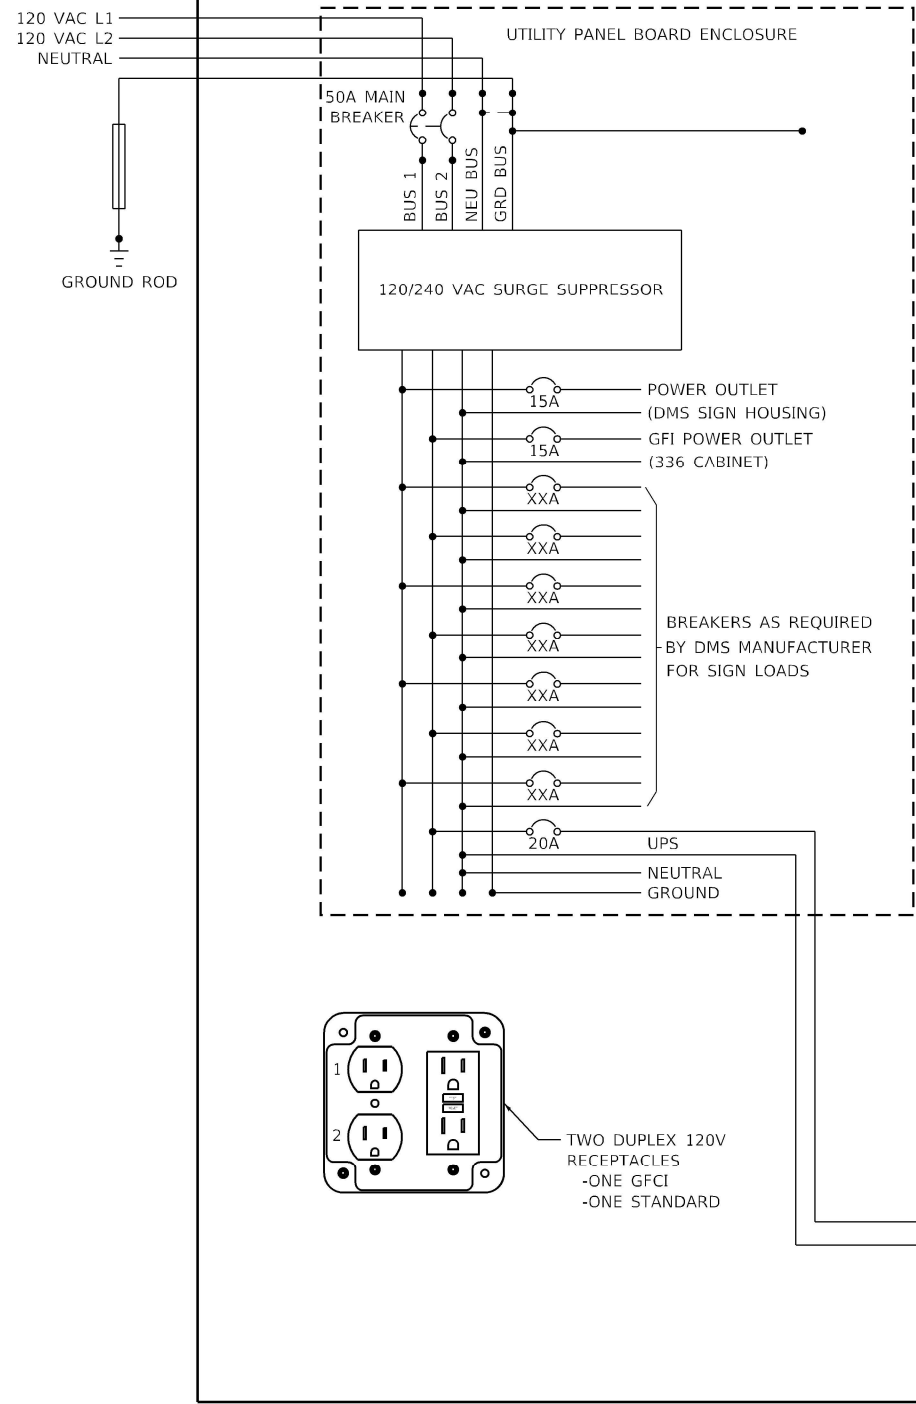

DMS HOUSING

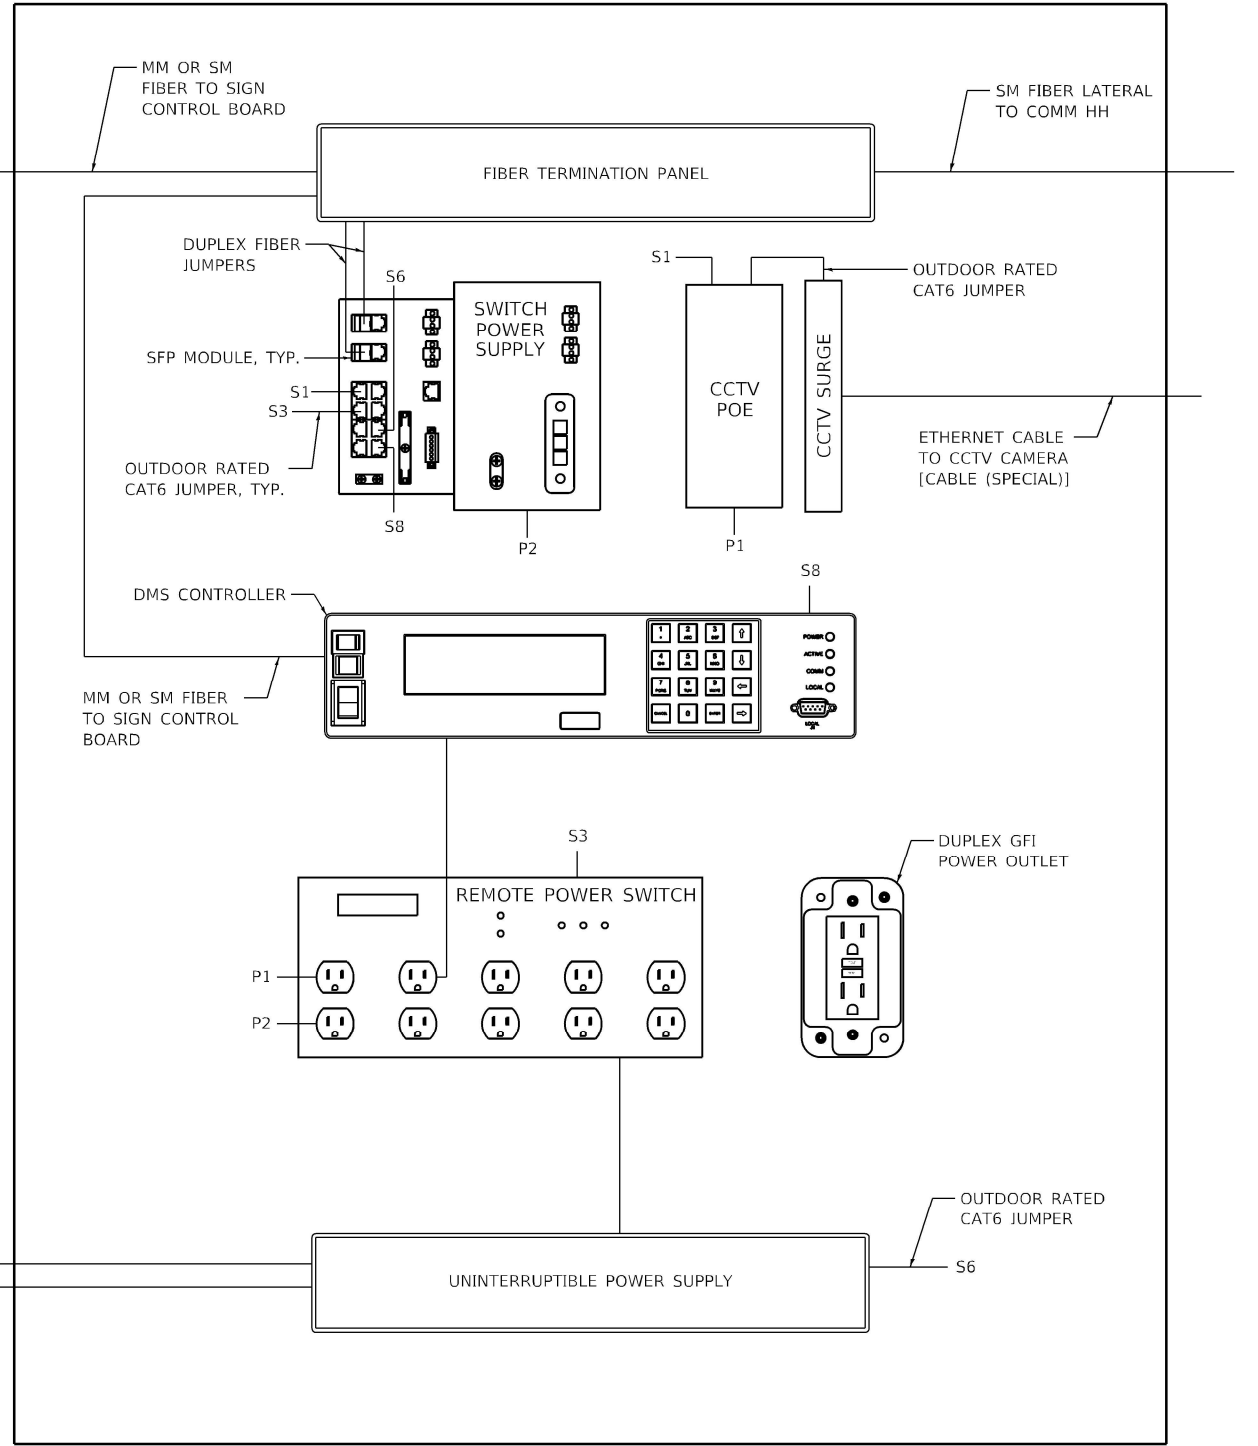


336S CABINET

NOTES

1. DMS MANUFACTURER TO PROVIDE WIRING DIAGRAMS/SCHEMATICS FOR REVIEW AND APPROVAL BY THE ENGINEER PRIOR TO FABRICATION.
2. ENTIRE COMPLETED SYSTEM SHALL BE GROUNDED AND BONDED IN ACCORDANCE WITH THE APPLICABLE ARTICLES OF SECTION 250 OF THE NATIONAL ELECTRICAL CODE.
3. EQUIPMENT SHOWN IN ABOVE DRAWING REPRESENTS GENERIC EQUIPMENT. EQUIPMENT SUPPLIED BY THE DMS MANUFACTURER MAY DIFFER IN APPEARANCE.

USER NAME = dmeier	DESIGNED - DJM	REVISED -
	DRAWN - DJM	REVISED -
PLOT SCALE = 2.0000 ' / in.	CHECKED - REL	REVISED -
PLOT DATE = 1/24/2025	DATE -	REVISED -


F.A.P. RTE.	SECTION	COUNTY	TOTAL SHEETS	SHEET NO.
307	2020-263-SUR,SW&TS	DUPAGE	529	492
CONTRACT NO. 62N33				
ILLINOIS FED. AID PROJECT				

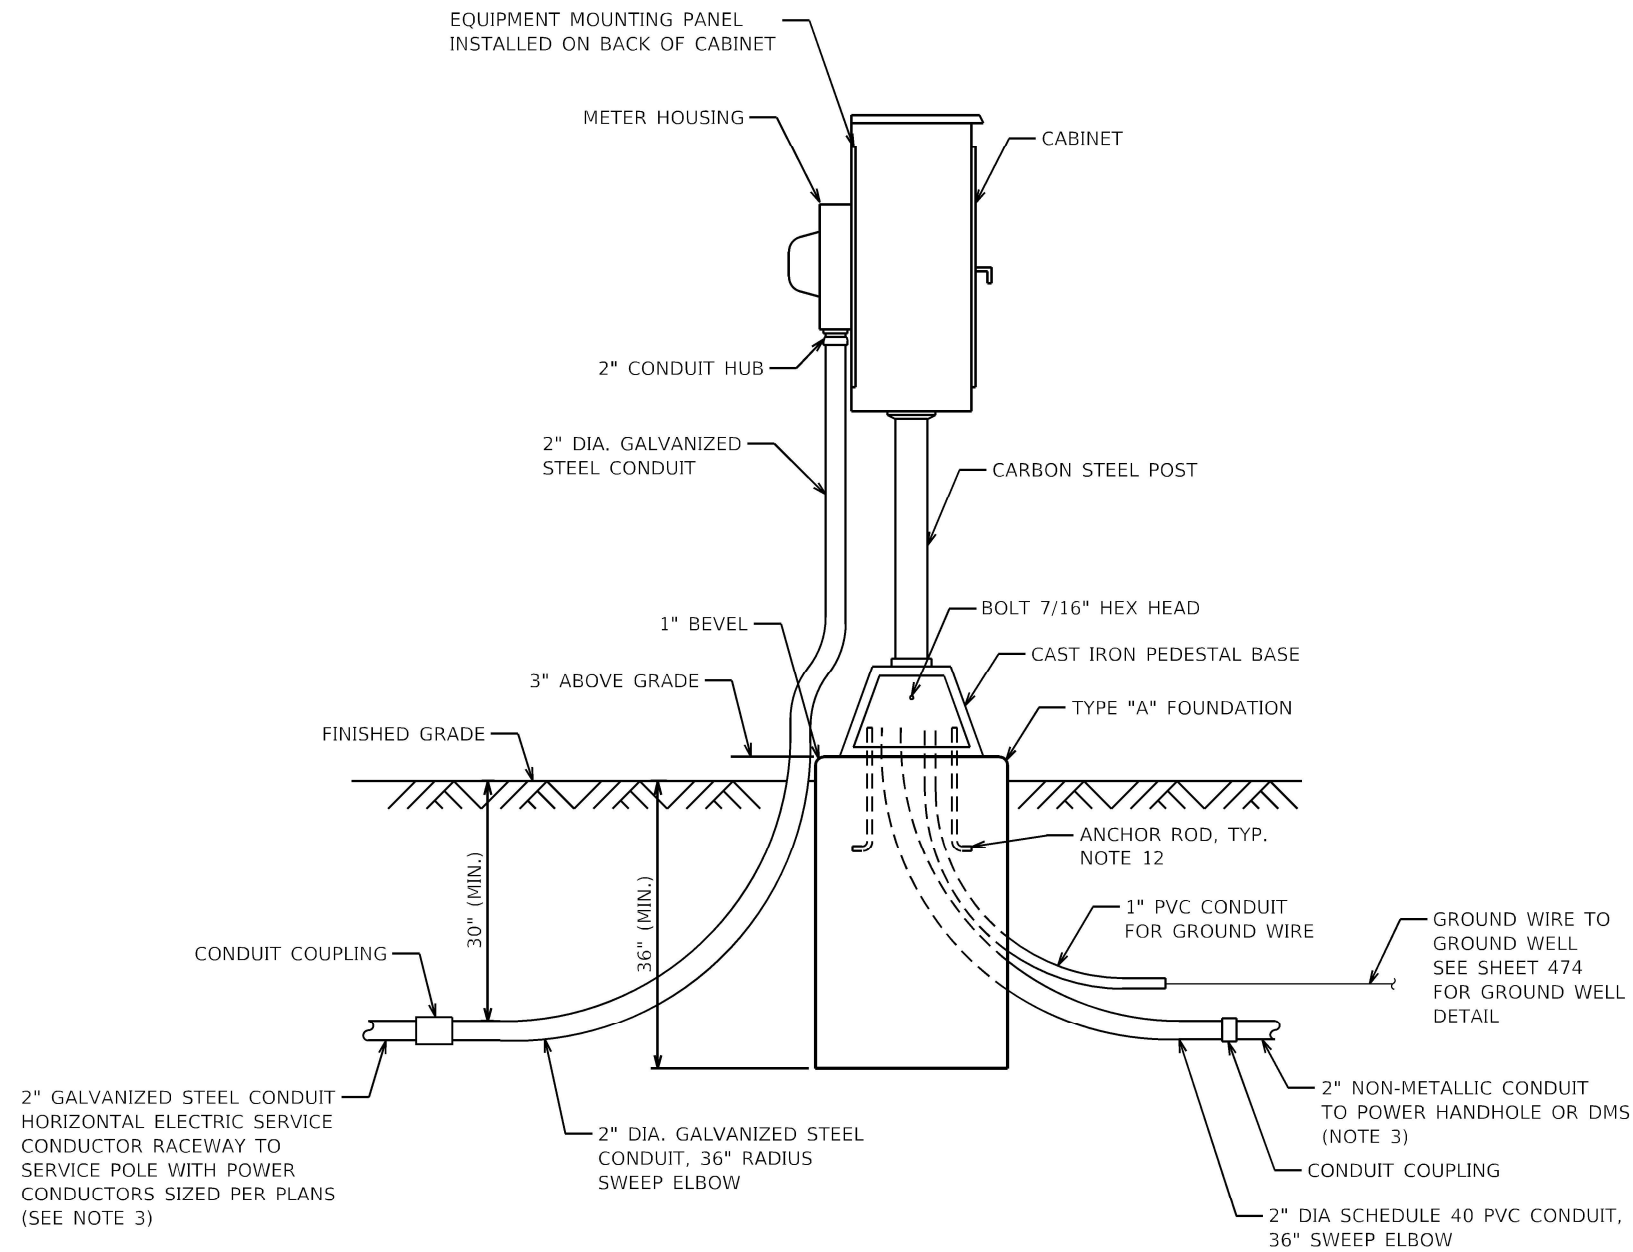

SERVICE PEDESTAL WITH METER

NOTES

1. SERVICE VOLTAGE SHALL BE AS INDICATED ELSEWHERE IN THE DRAWINGS.
2. UNLESS OTHERWISE INDICATED, ALL ITEMS AND WORK SHOWN SHALL BE INCLUDED AND PAID AS PART OF PAY ITEM 80400100 (ELECTRIC SERVICE INSTALLATION).
3. THE HORIZONTAL ELECTRIC SERVICE CONDUCTOR RACEWAY/CONDUCTORS AND NON-METALLIC CONDUIT TO POWER HANDHOLE SHALL BE MEASURED SEPARATELY FOR PAYMENT.
4. CABINETS, CABINET POSTS, AND CABINET PEDESTALS SHALL BE PRIMED AND PAINTED. THE EXTERIOR SHALL HAVE TWO EPOXY FINISH COATS OF ANSI-61 GRAY. THE INTERIOR SHALL BE PAINTED WHITE.
5. METER HOUSING SHALL BE MOUNTED TO BACK WALL OF CABINET.
6. CABLES FROM METER HOUSING SHALL PASS THROUGH BACK WALL OF CABINET.
7. METER HOUSING SHALL BE AS REQUIRED BY THE UTILITY.
8. THE CABINET SHALL BE 36"H X 20"W X 15"D, FABRICATED FROM ALUMINUM WITH A MINIMUM THICKNESS OF 0.125", RATED NEMA TYPE 3R AND HAVE A MOUNTING BACK PLATE.
9. THE CABINET DOOR SHALL HAVE A CONTINUOUS HINGE THAT IS BOLTED TO THE CABINET AND DOOR WITH 1/4-20 STAINLESS STEEL CARRIAGE BOLTS AND NY-LOCK NUTS. THE HINGE SHALL BE INSTALLED ON THE RIGHT SIDE WHEN FACING THE CABINET AND BE MADE OF STAINLESS STEEL WITH A 0.25 INCH DIAMETER STAINLESS STEEL HINGE PIN. THE HINGE PIN SHALL BE CAPPED TOP AND BOTTOM BY WELD TO RENDER IT TAMPER-PROOF. THE CABINET SHALL HAVE A GASKET THAT FORMS A WEATHER-TIGHT SEAL BETWEEN THE CABINET AND DOOR. THE DOOR LATCHING MECHANISM SHALL BE A 3-POINT DRAW ROLLER TYPE. WHEN THE DOOR IS CLOSED AND LATCHED, IT WILL BE LOCKED. THE LATCHING HANDLE SHALL BE FABRICATED FROM A 0.75" STAINLESS STEEL ROUND BAR AND SHALL HAVE A PROVISION FOR PADLOCKING IN THE CLOSED POSITION.
10. THE ENCLOSURE SHALL BE EQUIPPED WITH TWO ADJUSTABLE "C" MOUNTING CHANNELS WELDED ON BOTH SIDE WALLS AND BACK WALL OF THE ENCLOSURE, ALLOWING VERSATILE POSITIONING OF SHELVES OR PANELS. MOUNTING CHANNELS SHALL BE FACTORY PAINTED SAME COLOR AS INTERIOR OF CABINET.
11. THE CABINET DOOR SHALL NOT HAVE COPARTMENT DOORS OR LOUVERS. INTERIOR OF CABINET DOOR SHALL HAVE A PLASTIC POCKET FOR WIRING SCHEMATIC.
12. CONTRACTOR MUST COORDINATE WITH PEDESTAL BASE SUPPLIER AND FURNISH THE NECESSARY ANCHOR RODS.
13. THE ELECTRIC SERVICE EQUIPMENT ASSEMBLY SHALL BE ASSEMBLED BY A UL 508A INDUSTRIAL CONTROL PANEL FABRICATOR. THE PANEL ASSEMBLY SHALL BE UL LABELED AND SUITABLE FOR USE AS SERVICE EQUIPMENT.
14. ALL EQUIPMENT SHALL BE GROUNDED AND BONDED IN ACCORDANCE WITH THE NATIONAL ELECTRICAL CODE AND THE NATIONAL ELECTRICAL SAFETY CODE.
15. SEE STANDARD BE-220, ELECTRIC SERVICE INSTALLATION AERIAL, REMOTE DISCONNECT FOR REQUIREMENTS AT UTILITY POLE.
16. PLANS AND DETAILS INDICATE THE GENERAL NATURE AND REQUIREMENTS. THEY DO NOT SHOW EVERY ACCESSORY AND ATTACHMENT, AND THEY DO NOT RELIEVE THE CONTRACTOR OF THE REQUIREMENTS OF THE SPECIFICATIONS AND SPECIAL PROVISIONS TO ASCERTAIN UTILITY REQUIREMENTS AND TO COORDINATE ACCORDINGLY. FURNISHING ALL ITEMS AND WORK NOT PROVIDED BY THE UTILITY, BUT NECESSARY FOR A COMPLETE SERVICE INSTALLATION IS REQUIRED AND SHALL BE INCLUDED IN PAY ITEM 80400100 (ELECTRIC SERVICE INSTALLATION).

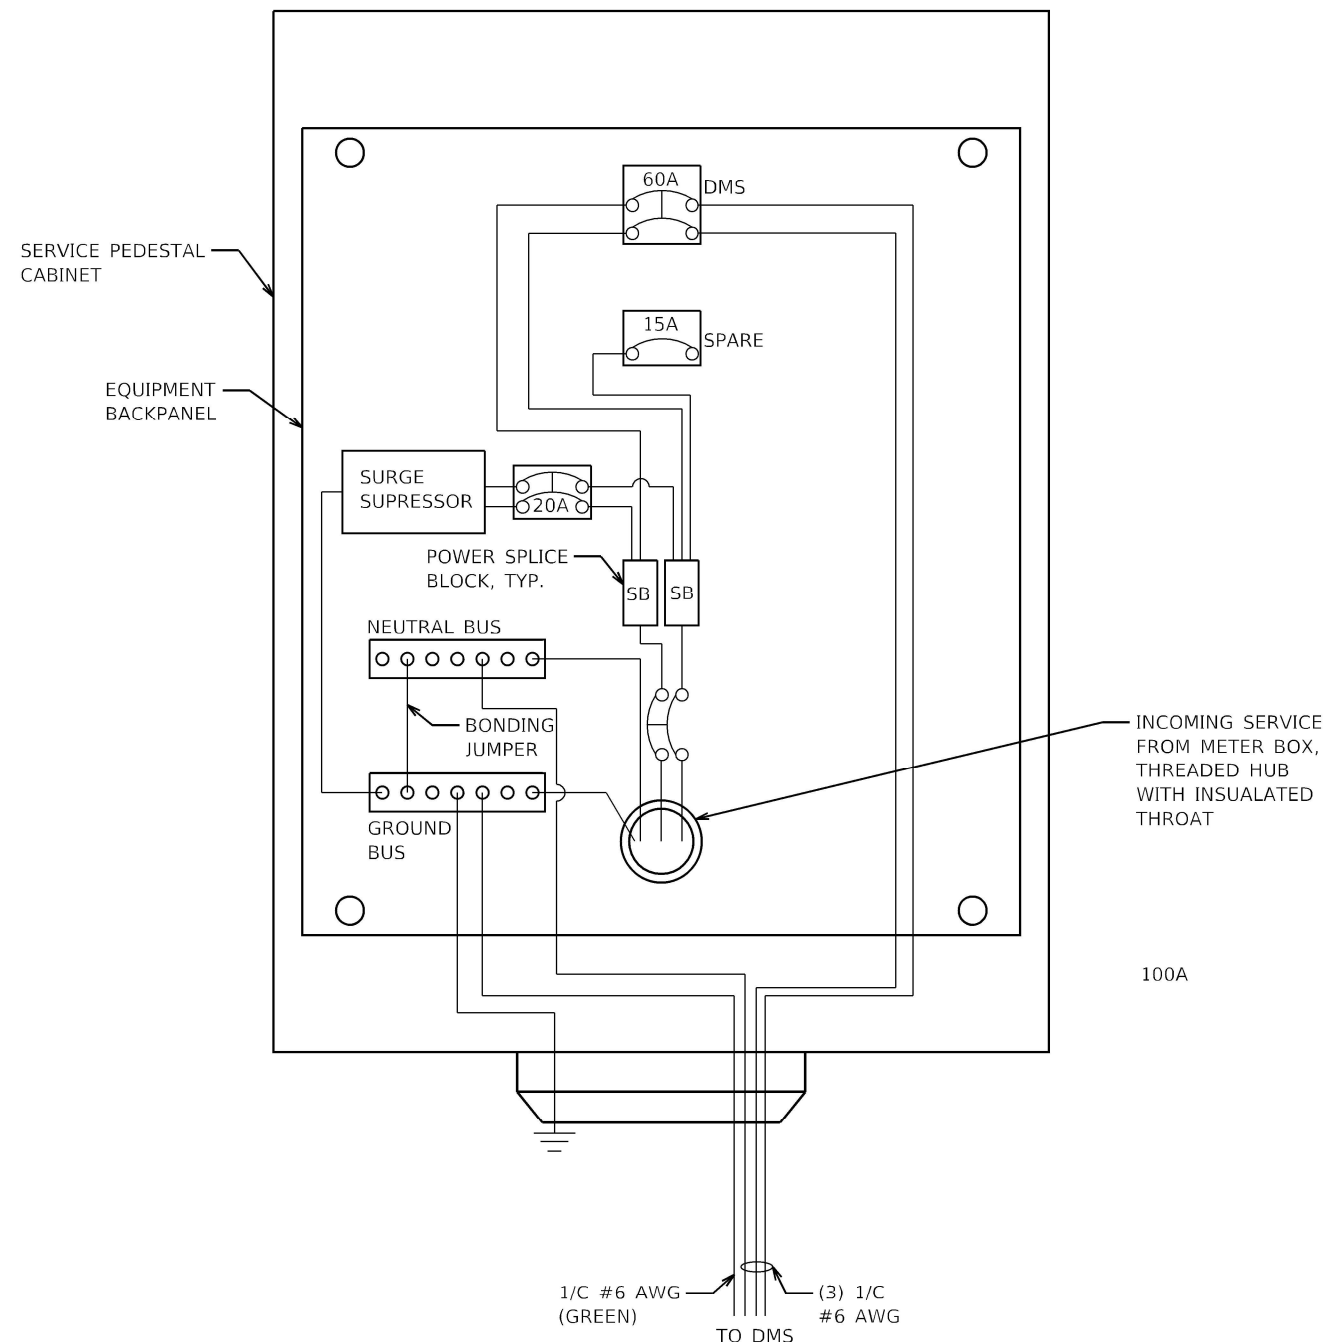

SERVICE PEDESTAL CABINET WIRING

NOTES

1. THE ELECTRIC SERVICE EQUIPMENT ASSEMBLY SHALL BE UL LABELED, SUITABLE FOR USE AS SERVICE EQUIPMENT.
2. CIRCUIT BREAKERS SHALL BE THERMAL MAGNETIC BOLT-ON TYPE WITH A MINIMUM INTERRUPTING CAPACITY OF 65,000 SYMETRICAL AMPERES RATED AT 240 VOLTS LINE TO LINE SERVICE OR 14,000 AT 480V RATED LINE TO LINE SERVICE. THEY SHALL BE LOCKABLE IN THE "OFF" POSITION FOR COMPLIANCE WITH OSHA LOCK-OUT/TAG-OUT REQUIREMENTS. HANDLES SHALL BE TRIP FREE.
3. THE SURGE PROTECTOR SHALL BE SUITABLE FOR THE INCOMING SINGLE PHASE 60HZ AC ELECTRICAL SERVICE, WITH A SURGE CURRENT RATING OF 50,00 AMPS OR BETTER, RATED -40 TO 65 DEGREES C., WITH LED OPERATING IDICATORS, AND SHALL BE UL LISTED PER UL 1449. SURGE PROTECTOR SHALL BE WIRED FOR THE INCOMING SERVICE VOLTAGE. FOLLOW MANUFACTURER RECOMMENDED WIRING SPECIFICATIONS.

4. BUS BARS, CONNECTORS AND LUGS SHALL BE COPPER, INSULATED AND ISOLATED AND CONFIGURED TO PREVENT SHORTED CONDITIONS FROM TIGHTENING TERMINATIONS, ETC. THE OVERALL BUS SECTION SHALL BE CONFIGURED BEHIND AN INSULATING BARRIER SHIELD WHICH IS REMOVABLE FOR ACCESS TO CONNECTIONS.
5. EQUIPMENT IN DIAGRAMS ABOVE ARE NOT TO SCALE AND WIRING IS DIAGRAMMATIC. CONTRACTOR TO SUBMIT WIRING DIAGRAM AND EQUIPMENT LAYOUT FOR APPROVAL BY THE ENGINEER.
6. A PLASTIC LAMINATED CABINET LAYOUT DIAGRAM, CIRCUIT SCHEMATIC, AND BILL OF MATERIALS WITH CATALOG NUMBERS USED SHALL BE AFFIXED TO THE INTERIOR SIDE OF THE ENCLOSURE DOOR.
7. A 2-COLOR ENGRAVED PLASTIC NAMEPLATE, ATTACHED WITH SCREWS, AND ENGRAVED AS INDICATED, SHALL BE PROVIDED FOR EACH BREAKER.

GENERAL NOTES

DESIGN: AASHTO Standard Specifications for Structural Supports for Highway Signs, Luminaires and Traffic Signals. ("AASHTO Specifications")

CONSTRUCTION: Current (at time of letting) Illinois Department of Transportation Standard Specifications for Road and Bridge Construction, Supplemental Specifications and Special Provisions. ("Standard Specifications")

LOADING: 90 M.P.H. WIND VELOCITY

WALKWAY LOADING: Dead load plus 500 lbs. concentrated live load.

DESIGN STRESSES:
Field Units
f'c = 3,500 p.s.i.
fy = 60,000 p.s.i. (reinforcement)

WELDING: All welds to be continuous unless otherwise shown. All welding to be done in accordance with current AWS D1.1 and D1.2 Structural Welding Codes (Steel and Aluminum) and the Standard Specifications.

MATERIALS: Aluminum Alloys as shown throughout plans. All Structural Steel Pipe shall be ASTM A53 Grade B or A500 Grade B or C. If A500 pipe is substituted for A53, then the outside diameter shall be as detailed and wall thickness greater than or equal to A53.
All Structural Steel Plates and Shapes shall conform to AASHTO M270 Gr. 36, Gr. 50 or Gr. 50W*. Stainless steel for shims, sleeves and handhole covers shall be ASTM A240, Type 302 or 304, or another alloy suitable for exterior exposure and acceptable to the Engineer.
The steel pipe and stiffening ribs at the base plate for the column shall have a minimum longitudinal Charpy V-Notch (CVN) energy of 15 lb.-ft. at 40° F. (Zone 2) before galvanizing.

FASTENERS FOR ALUMINUM TRUSSES: All bolts noted as "high strength" must satisfy the requirements of AASHTO M164 (ASTM A325), or approved alternate, and must have matching lock nuts. Threaded studs for splices (if Members interfere) must satisfy the requirements of ASTM A449, ASTM A193, Grade B7, or approved alternate, and must have matching lock nuts. Bolts and lock nuts not required to be high strength must satisfy the requirements of ASTM A307. All bolts and lock nuts must be hot dip galvanized per AASHTO M232. The lock nuts must have nylon or steel inserts. A stainless steel flat washer conforming to ASTM A240 Type 302 or 304, is required under both head and nut or under both nuts where threaded studs are used. High strength bolt installation shall conform to Article 505.04 (f) (2)d of the IDOT Standard Specifications for Road and Bridge Construction. Rotational capacity ("ROCAP") testing of bolts will not be required.

U-BOLTS AND EYEBOLTS: U-Bolts and Eyebolts must be produced from ASTM A276 Type 304, 304L, 316 or 316L, Condition A, cold finished stainless steel, or an equivalent material acceptable to the Engineer. All nuts for U-Bolts and Eyebolts must be lock nuts equivalent to ASTM A307 with nylon or steel inserts and hot dip galvanized per AASHTO M232. A stainless steel flat washer conforming to ASTM A240, Type 302 or 304, is required under each U-Bolt and Eyebolt lock nut.

GALVANIZING: All Steel Grating, Plates, Shapes and Pipe shall be Hot Dip Galvanized after fabrication in accordance with AASHTO M111. Painting is not permitted.

ANCHOR RODS: Shall conform to ASTM F1554 Gr. 105.

CONCRETE SURFACES: All concrete surfaces above an elevation 6" below the lowest final ground line at each foundation shall be cleaned and coated with Concrete Sealer in accordance with the Standard Specifications.

REINFORCEMENT BARS: Reinforcement Bars designated (E) shall be epoxy coated in accordance with the Standard Specifications.


FOUNDATIONS: The contract unit price for Drilled Shaft Concrete Foundations shall include reinforcement bars complete in place.

TOTAL BILL OF MATERIAL

ITEM	UNIT	TOTAL
OVERHEAD SIGN STRUCTURE CANTILEVER TYPE I-C-A	Foot	
OVERHEAD SIGN STRUCTURE CANTILEVER TYPE II-C-A	Foot	
OVERHEAD SIGN STRUCTURE CANTILEVER TYPE III-C-A	Foot	80
OVERHEAD SIGN STRUCTURE WALKWAY, TYPE A	Foot	
DRILLED SHAFT CONCRETE FOUNDATIONS	Cu. Yds.	25.0

Structure Number	Station	Design Truss Type	Cantilever Length (L)	Elev. A	Dim. D	Ds	Total Sign Area
1C022S064L000.0-003	1643+08	III-C-A	40'-0"	727.80	8'-8"	6'-0"	120 Sq. Ft.
1C022S064R000.0-001	1601+71	III-C-A	40'-0"	708.00	7'-1"	6'-0"	120 Sq. Ft.

Truss Type	Maximum Sign Area	Maximum Length
I-C-A	170 Sq. Ft.	25 Ft.
II-C-A	340 Sq. Ft.	30 Ft.
III-C-A	400 Sq. Ft.	40 Ft.

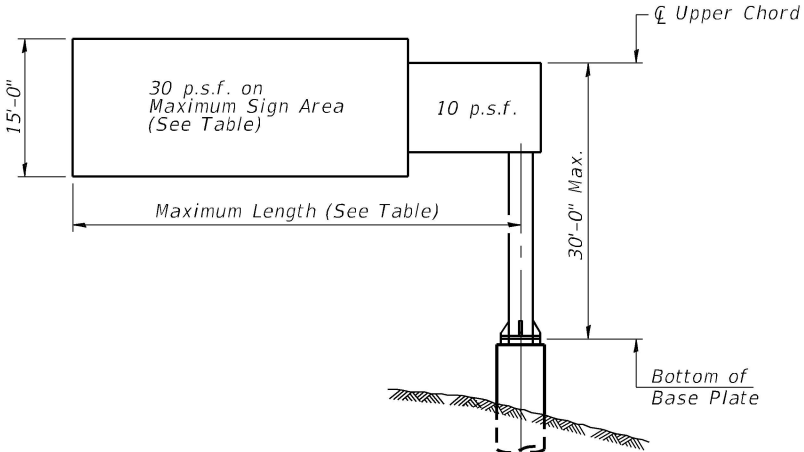


DESIGN WIND LOADING DIAGRAM

Parameters shown are basis for I.D.O.T. Standards
Installations not within dimensional limits shown
require special analysis for all components.


Note:
Trusses shall be shipped individually with adequate provision to prevent detrimental motion during transport. This may require ropes between horizontals and diagonals or energy dissipating (elastic) ties to the vehicle. The contractor is responsible for maintaining the configuration and protection of the trusses.

- ① After adjustments to level truss and insure adequate vertical clearance, all top and leveling nuts shall be tightened against the base plate with a minimum torque of 200 lb.-ft. Stainless steel mesh shall then be placed around the perimeter of the base plate. Secure to base plate with stainless steel banding.

* If M270 Gr. 50W (M222) steel is proposed, chemistry for plate to be used shall first be approved by the Engineer as suitable for galvanizing and welding.

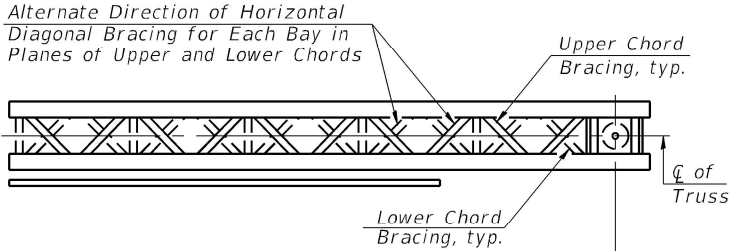

TYPICAL PLAN
(Walkway not shown)

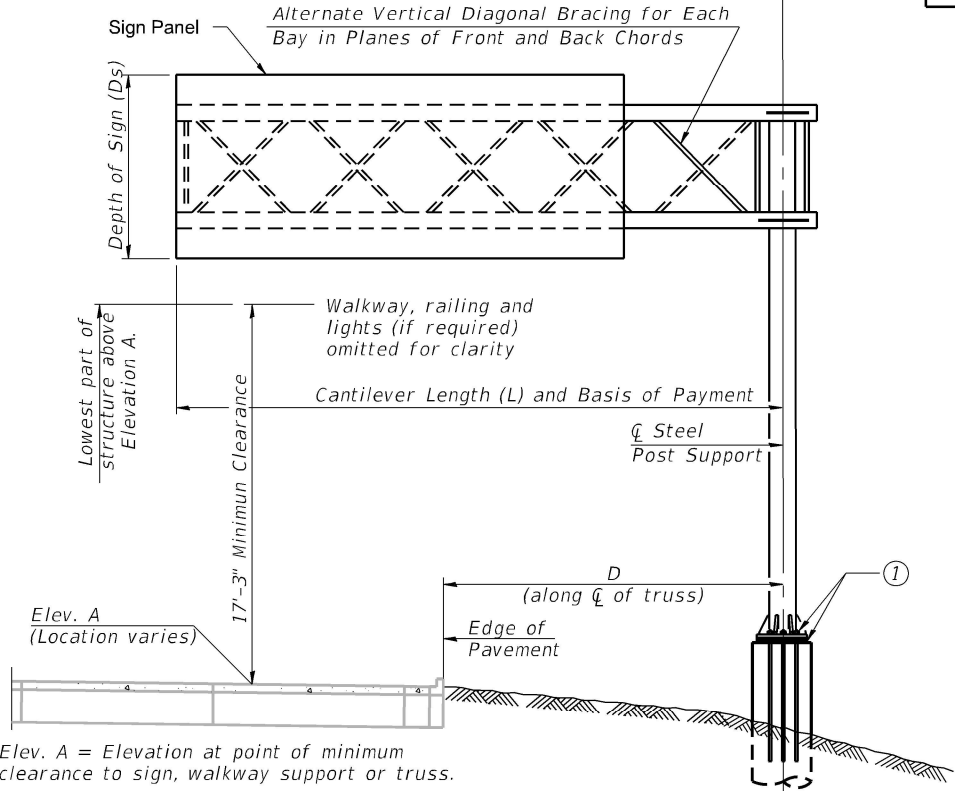

TYPICAL ELEVATION

Looking in Direction of Traffic

Sign support structures may be subject to damaging vibrations and oscillations when sign panels are not in place during erection or maintenance of the structure. To avoid these vibrations and oscillations, consideration should be given to attaching temporary blank sign panels to the structure.

OSC-A-1

5-15-2023

TranSmart
100 S. Wacker Drive Suite 400
Chicago, Illinois 60606



USER NAME = dmeier	DESIGNED - ZC	REVISED -
	DRAWN - JDK	REVISED -
PLOT SCALE = 2.0000 ' / in.	CHECKED - AS	REVISED -
PLOT DATE = 1/24/2025	DATE -	REVISED -

STATE OF ILLINOIS
DEPARTMENT OF TRANSPORTATION


CANTILEVER SIGN STRUCTURE-GENERAL PLAN & ELEVATION
IL 64 (NORTH AVE) SMART CORRIDOR

SCALE: N.T.S. SHEET 1 OF 6 SHEETS STA. N/A TO STA. N/A


F.A.P. RTE.	SECTION	COUNTY	TOTAL SHEETS	SHEET NO.
307	2020-263-SUR,SW&TS	DUPAGE	529	495
CONTRACT NO. 62N33				
ILLINOIS FED. AID PROJECT				

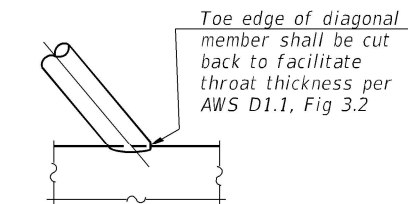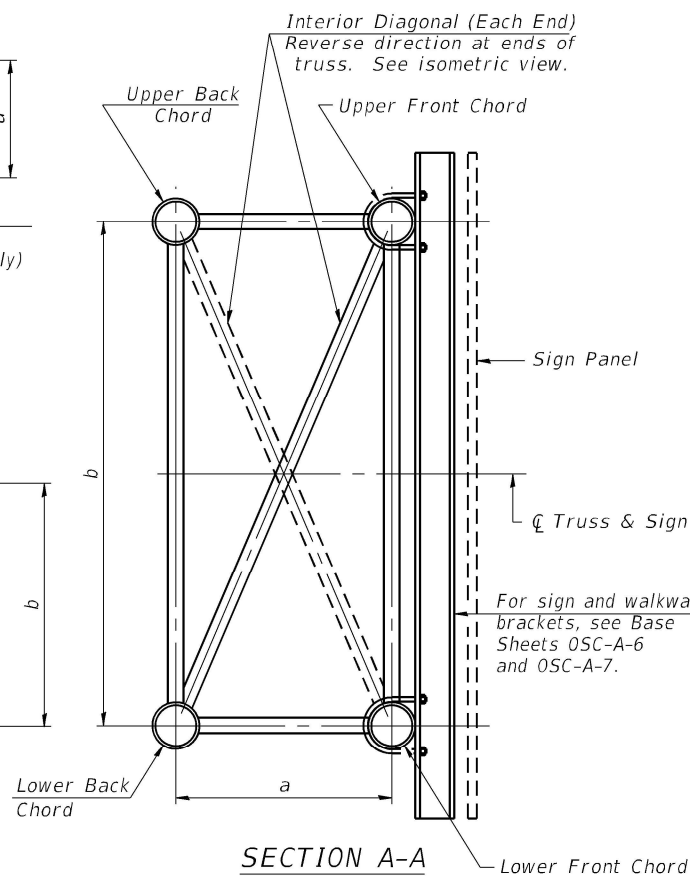

DETAIL A

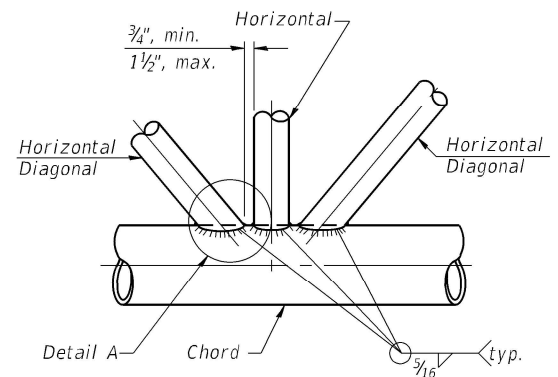


TRUSS INTERIOR JOINT DETAIL

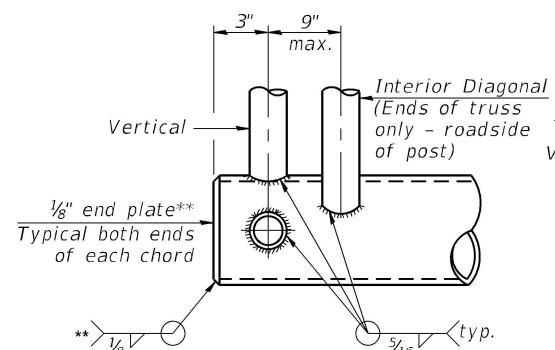

CANTILEVER END JOINT DETAIL

** Contractor may alternatively use standard aluminum drive-fit cap to close ends.
1/2" Ø Drain hole in end plate / drive-fit cap.

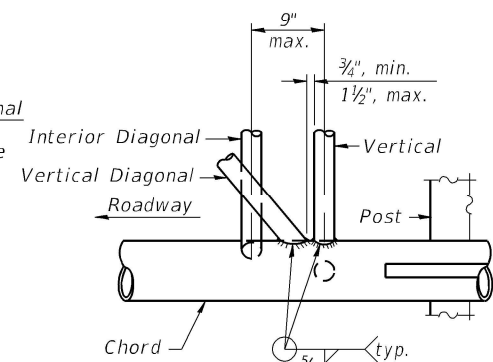

POST END JOINT DETAIL

TYPICAL TRUSS UNIT

For Section B-B and Section C-C, see Base Sheet OSC-A-3.

Note: There are twice as many horizontal diagonals as there are vertical diagonals.

TRUSS UNIT TABLE

The technical drawing illustrates the construction of a typical truss unit. The main isometric view shows a long truss structure with labels for 'Chord', 'Vertical', 'Horizontal', 'Diagonal Interior', 'Vertical Diagonal', 'Horizontal Diagonal', and 'Horizontal Diagonal (Lower Chord Only)'. A detailed inset titled 'CAMBER DIAGRAM (For Fabrication Only)' shows the 'Shop camber at end: measured without dead load deflection (See elevation of typical unit)' and a '90°' angle relative to the 'Roadway face of post'. A 'SHOP CAMBER TABLE' is provided below the main view, and a section titled 'ISOMETRIC VIEW TYPICAL TRUSS UNIT ASTM B221 Alloy 6061 Temper T6' is located at the bottom center.

Unit Length (L)	Shop Camber at End
15'	1½"
16'-17'	1¾"
18'-20'	2"
21'-22'	2¼"
23'-25'	2½"
26'-27'	2¾"
28'-30'	3"
31'-32'	3¼"
33'-35'	3½"
36'-37'	4"
38'-40'	4½"

SHOP CAMBER TABLE

Unit Length (L)	Shop Camber at End
15'	1½"
16'-17'	1¾"
18'-20'	2"
21'-22'	2¼"
23'-25'	2½"
26'-27'	2¾"
28'-30'	3"
31'-32'	3¼"
33'-35'	3½"
36'-37'	4"
38'-40'	4½"

ISOMETRIC VIEW
TYPICAL TRUSS UNIT
ASTM B221 Alloy 6061 Temper

CAMBER DIAGRAM
(For Fabrication Only)

OSC-A-2

5-15-2023

TranSmart
100 S. Wacker Drive Suite 400
Chicago, Illinois 60606

USER NAME = dmeler	DESIGNED - ZC	REVISED -
	DRAWN - JDK	REVISED -
PLOT SCALE = 2.0000 ' / in.	CHECKED - AS	REVISED -
PLOT DATE = 1/24/2025	DATE -	REVISED -

**STATE OF ILLINOIS
DEPARTMENT OF TRANSPORTATION**


CANTILEVER SIGN STRUCTURE-TRUSS DETAILS
IL 64 (NORTH AVE) SMART CORRIDOR

SCALE: N.T.S.	SHEET 2	OF 6	SHEETS	STA. N/A	TO STA. N/A
---------------	---------	------	--------	----------	-------------

F.A.P. RTE.	SECTION	COUNTY	TOTAL SHEETS	SHEET NO.
307	2020-263-SUR, SW&TS	DUPAGE	529	496
		CONTRACT NO. 62N33		
		ILLINOIS	FED. AID PROJECT	

MODEL: Default

MODEL: Default
FILE: Smart - project - pva-bentley.com\ksp\pva-d1\Documents\01 Active Projects\MW-CHS-168959\100 - IL 64\Phase II\2 Design\CAD\Draw Sheets\TSS\slshp\DNS\West Corridor\00812141-rd03 TSM.dgn

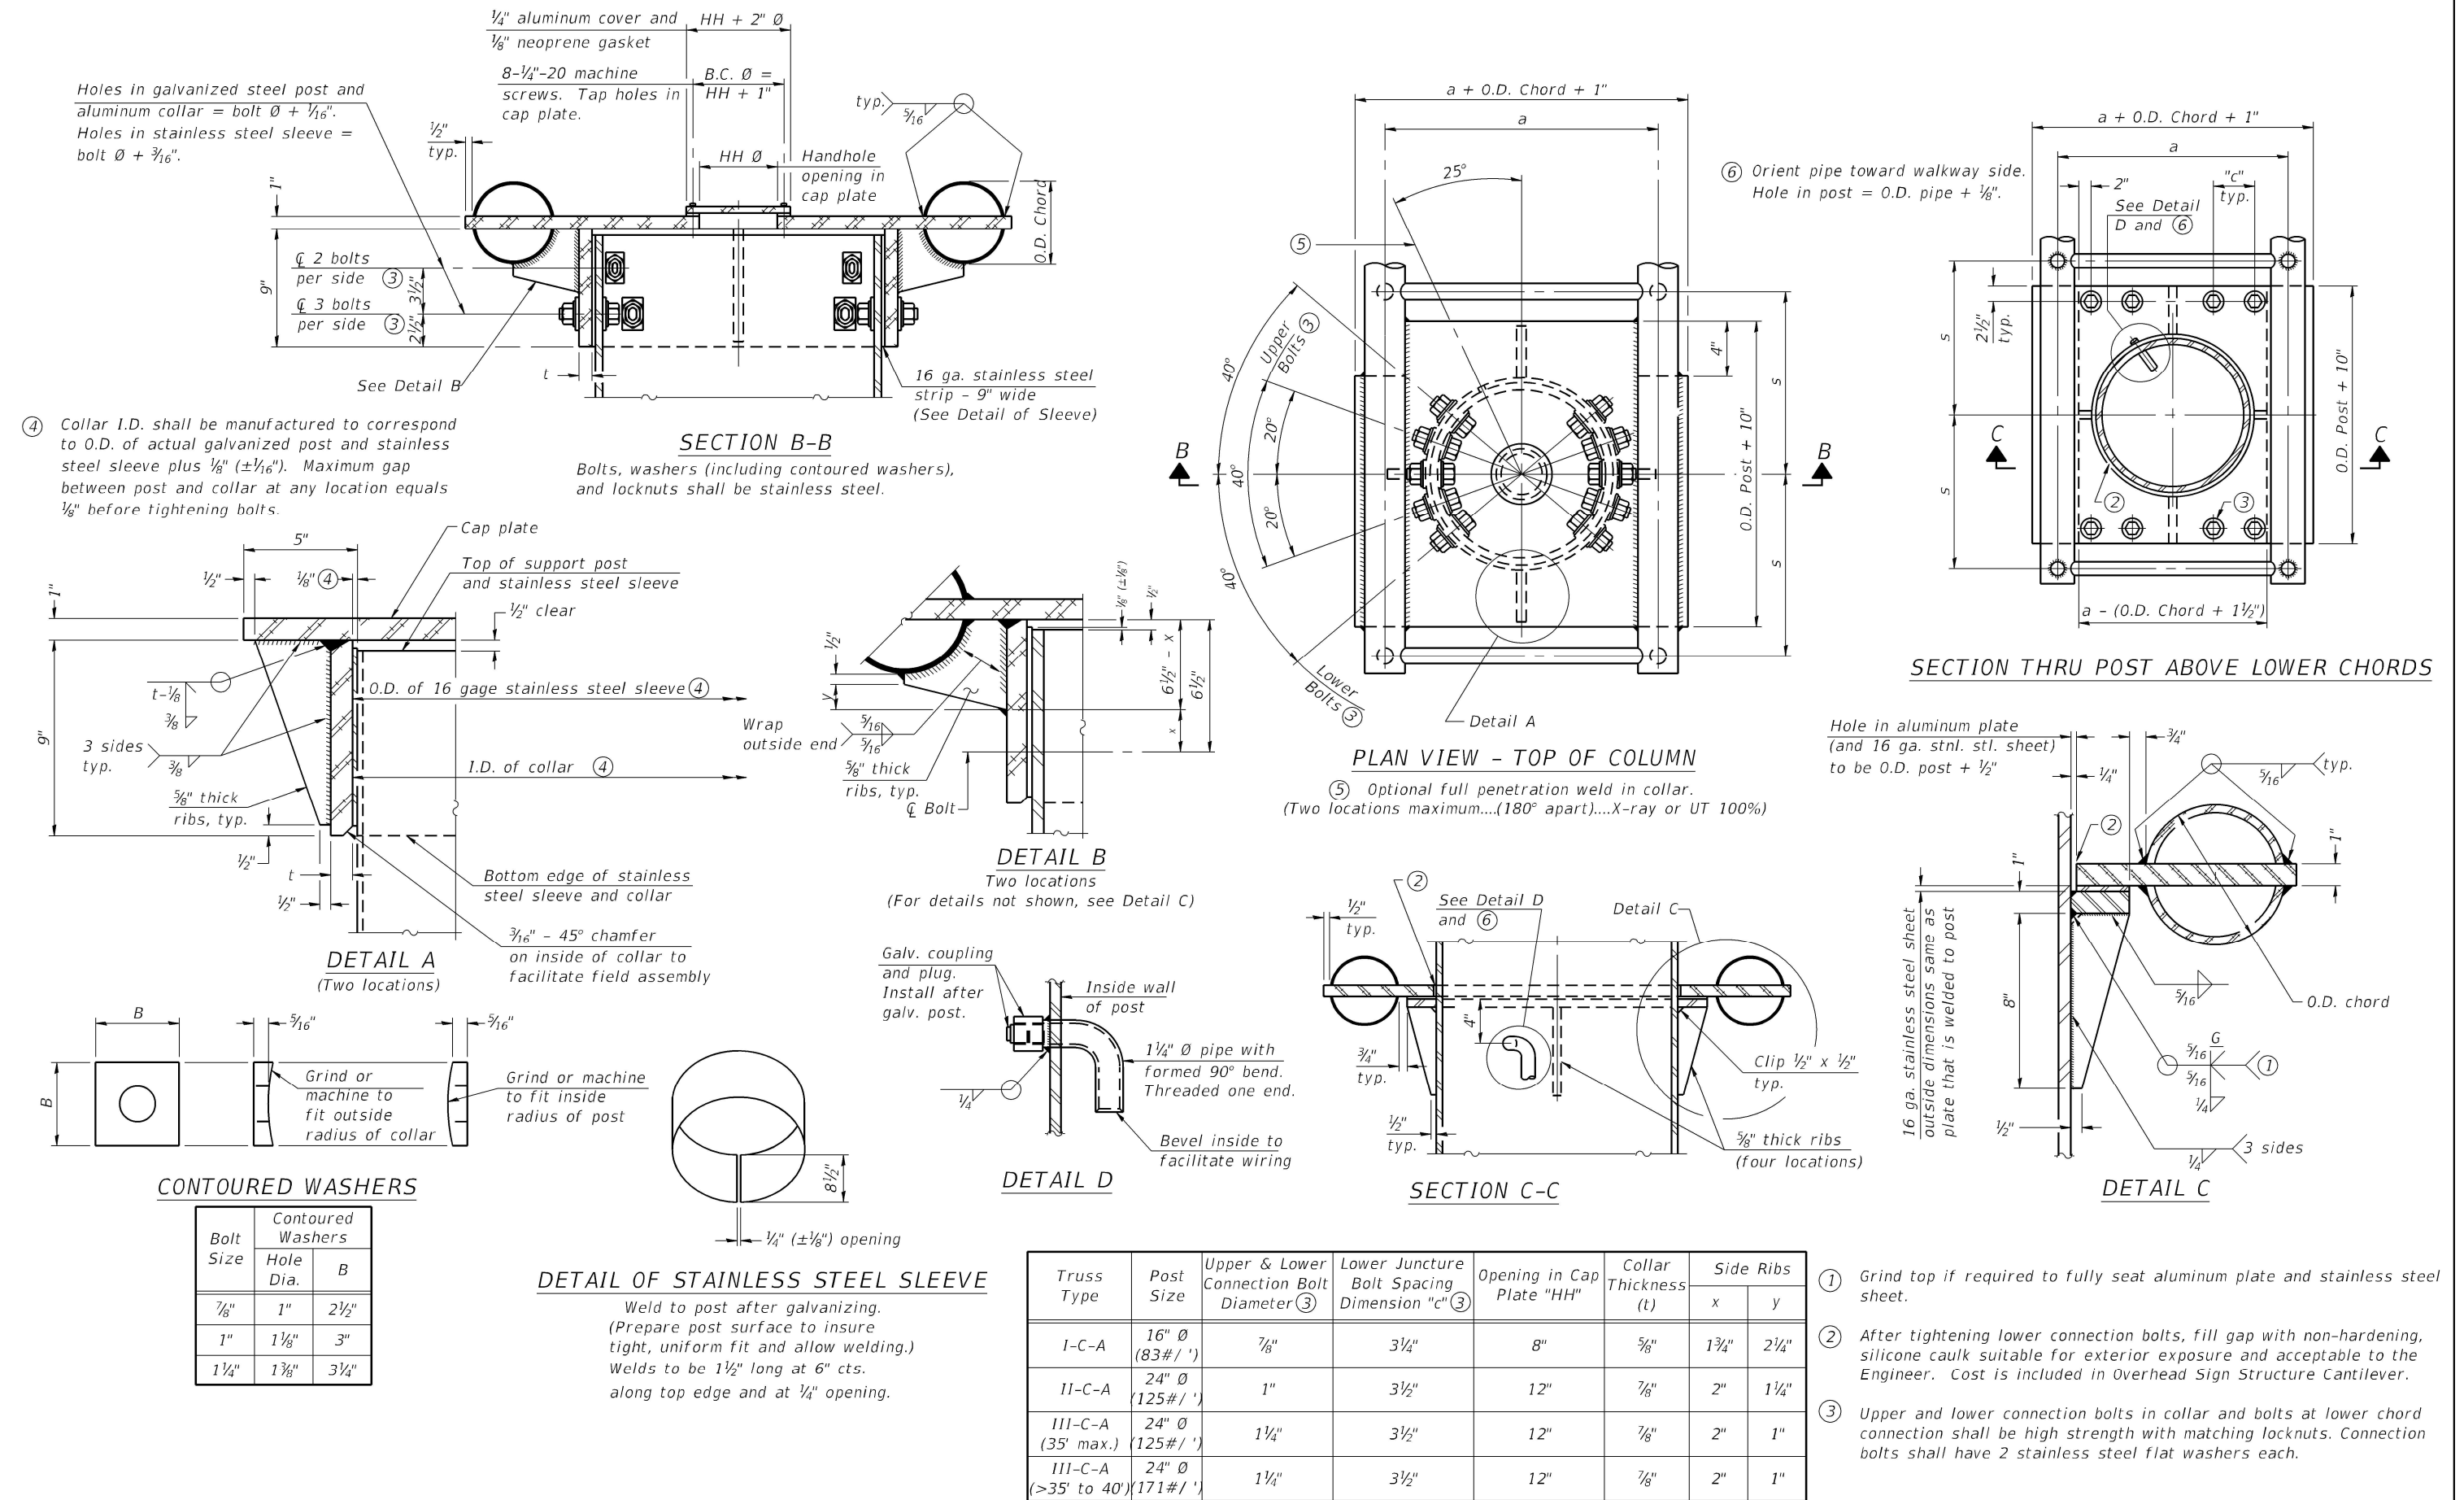

OSC-A-3

5-15-2023

TranSmart
100 S. Wacker Drive Suite 400
Chicago, Illinois 60606








USER NAME = dmeier	DESIGNED - ZC	REVISED -
DRAWN - JDK	REVISED -	
PLOT SCALE = 2.0000 ' / in.	CHECKED - AS	REVISED -
PLOT DATE = 1/24/2025	DATE -	REVISED -

STATE OF ILLINOIS
DEPARTMENT OF TRANSPORTATION

CANTILEVER SIGN STRUCTURES-JUNCTURE DETAILS
IL 64 (NORTH AVE) SMART CORRIDOR


SCALE: N.T.S. SHEET 3 OF 6 SHEETS STA. N/A TO STA. N/A

F.A.P. RTE.	SECTION	COUNTY	TOTAL SHEETS	SHEET NO.
307	2020-263-SUR,SW&TS	DUPAGE	529	497
CONTRACT NO. 62N33				
ILLINOIS FED. AID PROJECT				

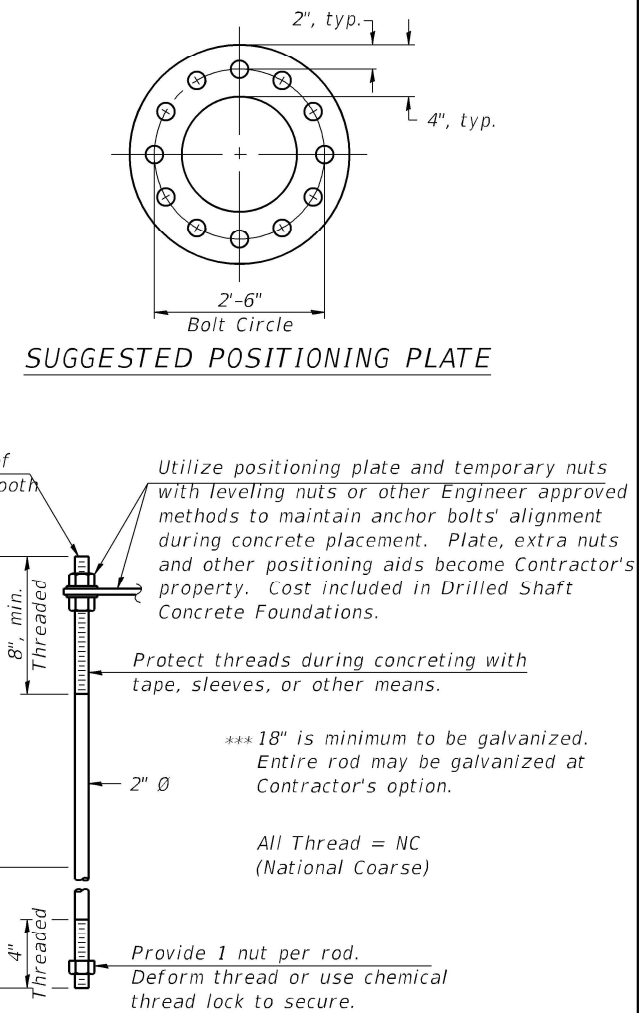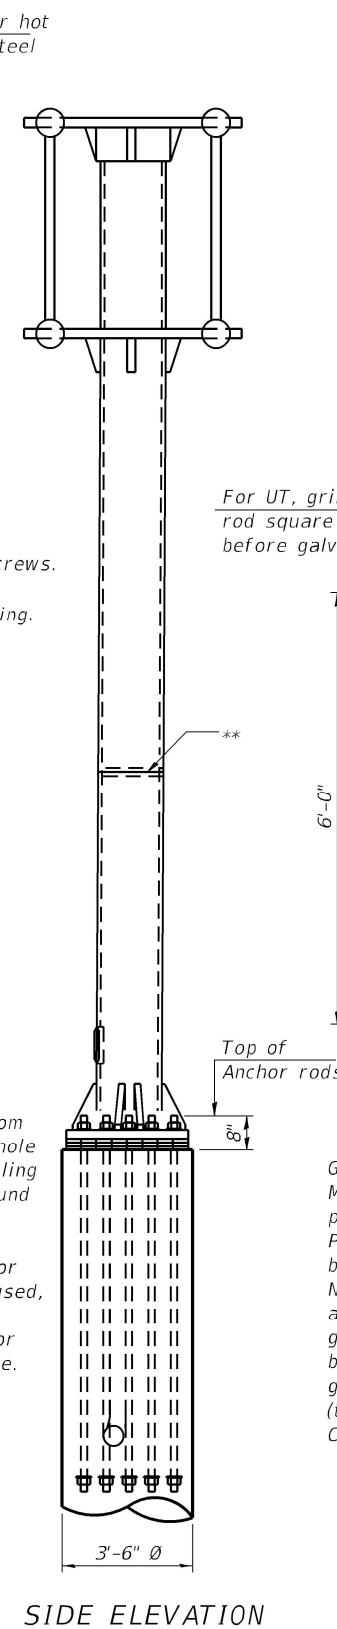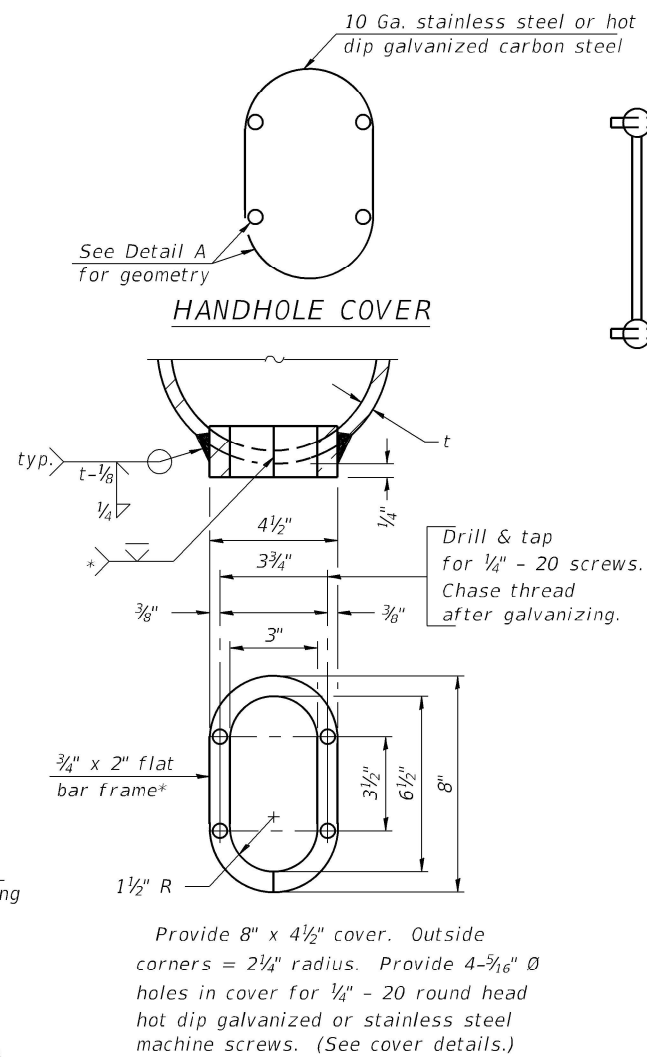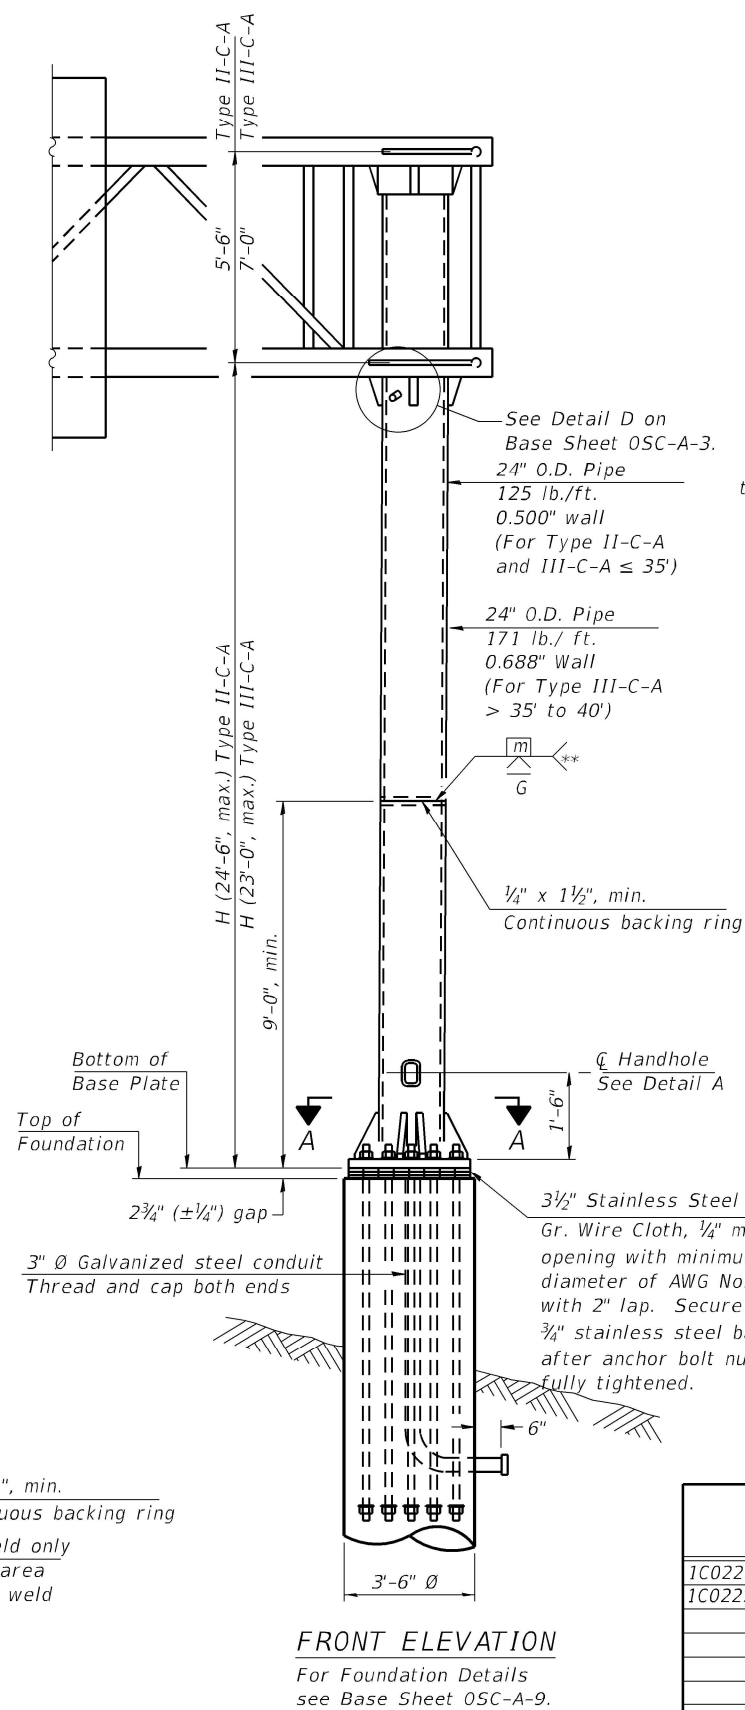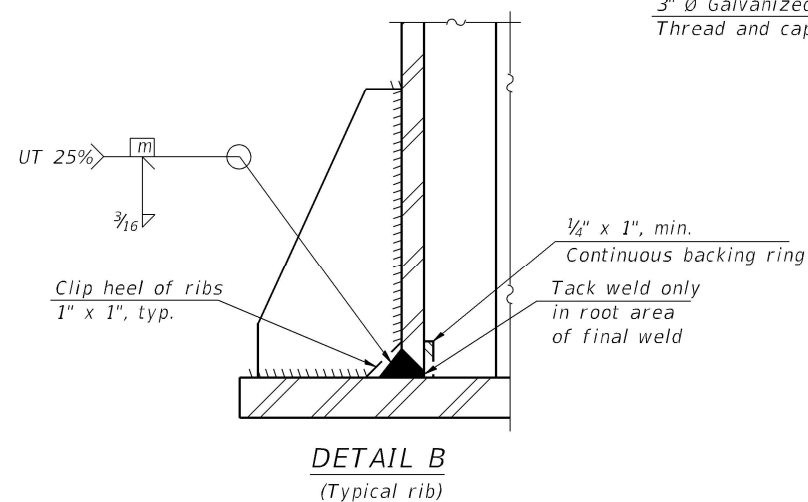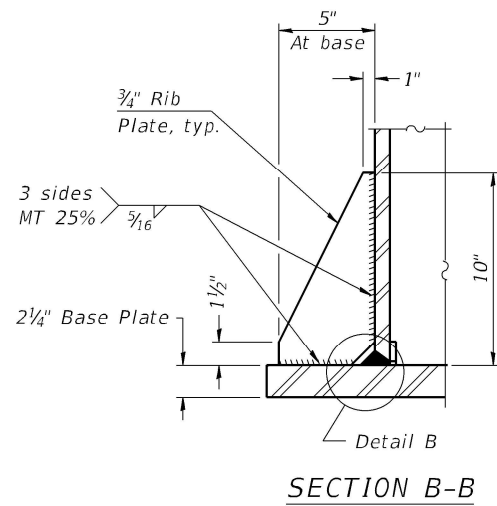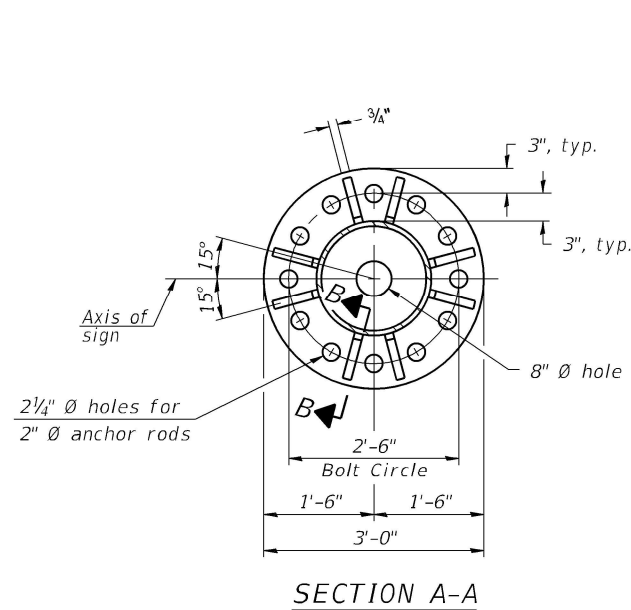
[illegible]

Note: "H" based on 15'-0" or actual sign height, whichever is greater.

* Grind anchor rod to bright finish at ground clamp location before installing clamp.

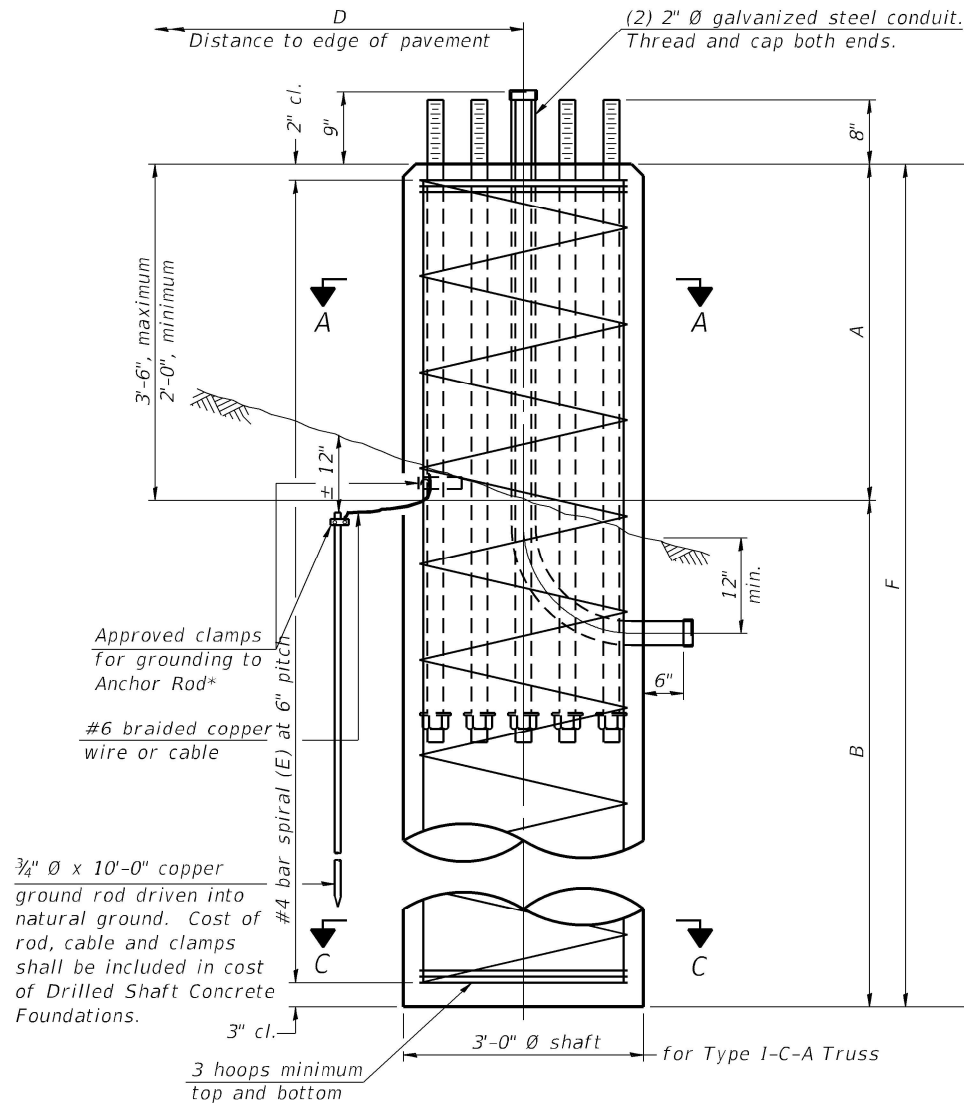

ELEVATION

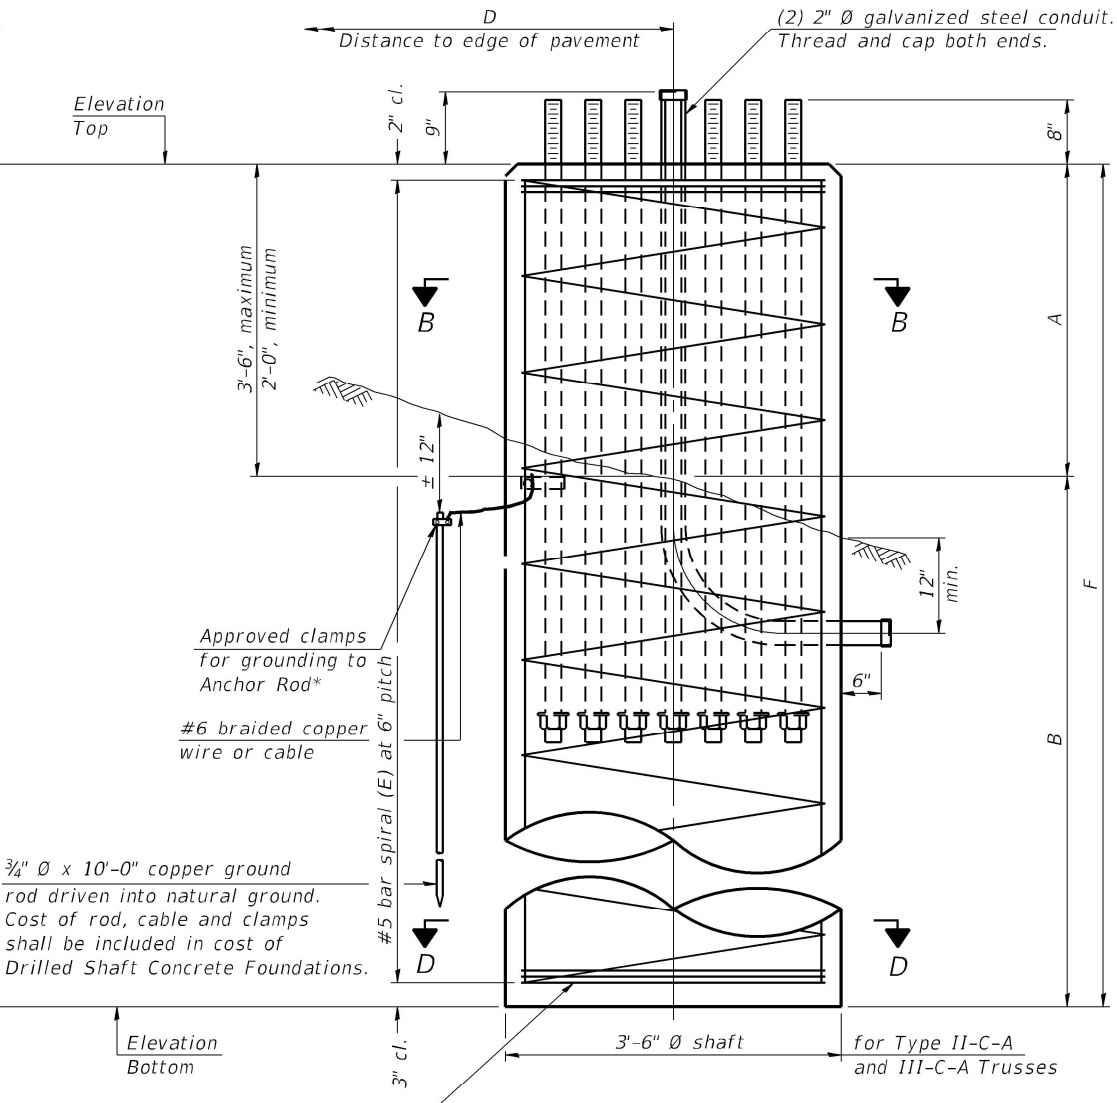

ELEVATION

NOTES:

The foundation dimensions shown in the Foundation Design Table are based on the presence of mostly cohesive soils with an average Unconfined Compressive Strength (Q_u) of at least 1.25 tsf, which must be determined by previous soil investigations at the jobsite. When other conditions are indicated, the boring data will be included in the plans and the foundation dimensions shown in the Foundation Data Table will be the result of site specific designs.

If the conditions encountered are different than those indicated, the Contractor shall notify the Engineer to determine if the foundation dimensions need to be modified. If dimensions "B" or "F" are revised by more than 12" by the Contractor, "as-built" plans shall be prepared and submitted to the District Bureau of Operations for future reference.

No sonotubes or decomposable forms shall be used below the lower conduit entrance. Permanent metal forms or other shielding may not be left in place below that elevation without the Engineer's written permission.

Concrete shall be placed monolithically, without construction joints.

Backfill shall be placed per Article 502 of Standard Specification and prior to erection of support column.





A normal surface finish followed by a Concrete Sealer application will be required on concrete surfaces above the lowest elevation 6" below finished ground line. Cost included in "Drilled Shaft Concrete Foundation".

FOUNDATION DESIGN TABLE

Truss Type	Post Base Sheet	Maximum Cantilever Length (ft)	Maximum Total Sign Area (sq ft)	Shaft Diameter (in)	"B" Depth (ft)	Anchor Rods		Anchor Rod Circle Diameter (in)
						No.	Diameter (in)	
I-C-A	OSC-A-4	25	170	3.0	16.0	8	2	22
II-C-A	OSC-A-5	30	170	3.5	17.0	12	2	30
II-C-A	OSC-A-5	30	340	3.5	21.5	12	2	30
III-C-A	OSC-A-5	35	170	3.5	19.0	12	2	30
III-C-A	OSC-A-5	35	250	3.5	22.5	12	2	30
III-C-A	OSC-A-5	35	400	3.5	26.5	12	2	30
III-C-A	OSC-A-5	40	400	3.5	32.0	12	2	30

FOUNDATION DATA TABLE

Structure Number	Station	Truss Type	Shaft Diameter	Elevation Top	Elevation Bottom	Q_u	A	B	F	Class DS Concrete Cubic Yards
1C022S064L000.0-003	1643+08	III-C-A	3'-6"	731.30	696.30	-	2'-0"	33'-0"	35'-0"	12.5
1C022S064R000.0-001	1601+71	III-C-A	3'-6"	709.40	674.40	-	2'-0"	33'-0"	35'-0"	12.5

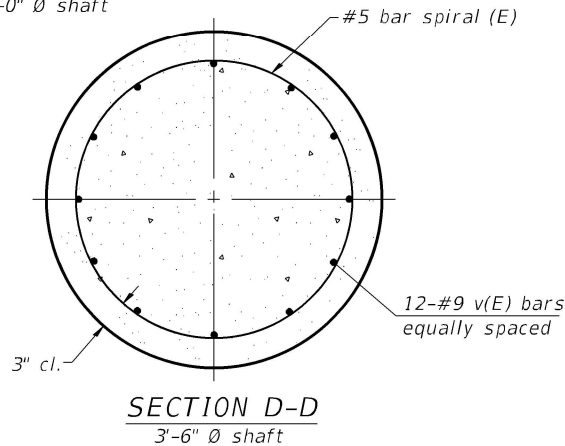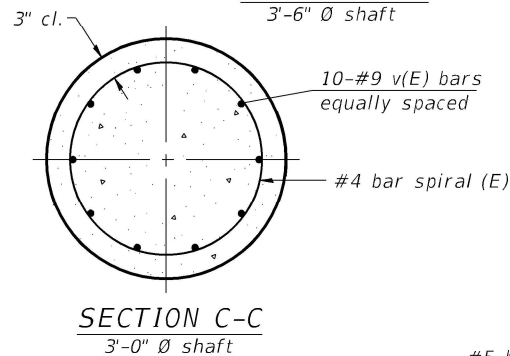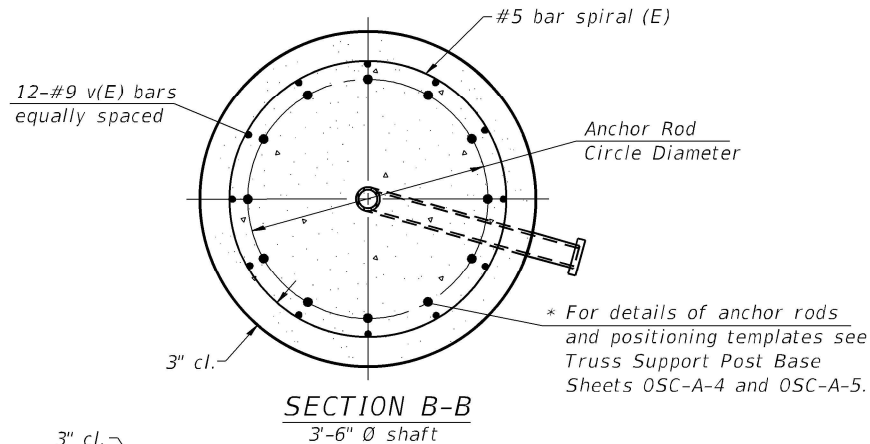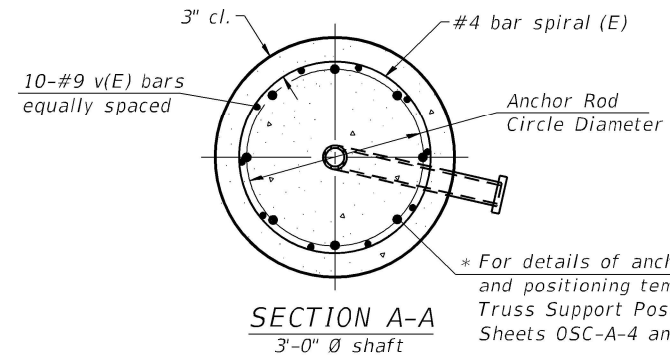

OSC-A-9

5-15-2023

TranSmart
100 S. Wacker Drive Suite 400
Chicago, Illinois 60606

USER NAME = dmeier	DESIGNED - ZC	REVISED -
	DRAWN - JDK	REVISED -
PLOT SCALE = 2.0000' / in.	CHECKED - AS	REVISED -
PLOT DATE = 1/24/2025	DATE -	REVISED -


STATE OF ILLINOIS
DEPARTMENT OF TRANSPORTATION

CANTILEVER SIGN STRUCTURES-DRILLED SHAFT FOUNDATION
IL 64 (NORTH AVE) SMART CORRIDOR


SCALE: N.T.S. SHEET 5 OF 6 SHEETS STA. N/A TO STA. N/A

F.A.P. RTE.	SECTION	COUNTY	TOTAL SHEETS	SHEET NO.
307	2020-263-SUR,SW&TS	DUPAGE	529	499
CONTRACT NO. 62N33				
ILLINOIS FED. AID PROJECT				


MODEL: Default
FILE: SmartSign-Structure-Details-OSC-A-D.dwg
PROJECT: SmartSign-Structure-Details-OSC-A-D.dwg
DATE: 5/15/2023
USER: dmeier
PROJECT: SmartSign-Structure-Details-OSC-A-D.dwg
DATE: 5/15/2023
USER: dmeier

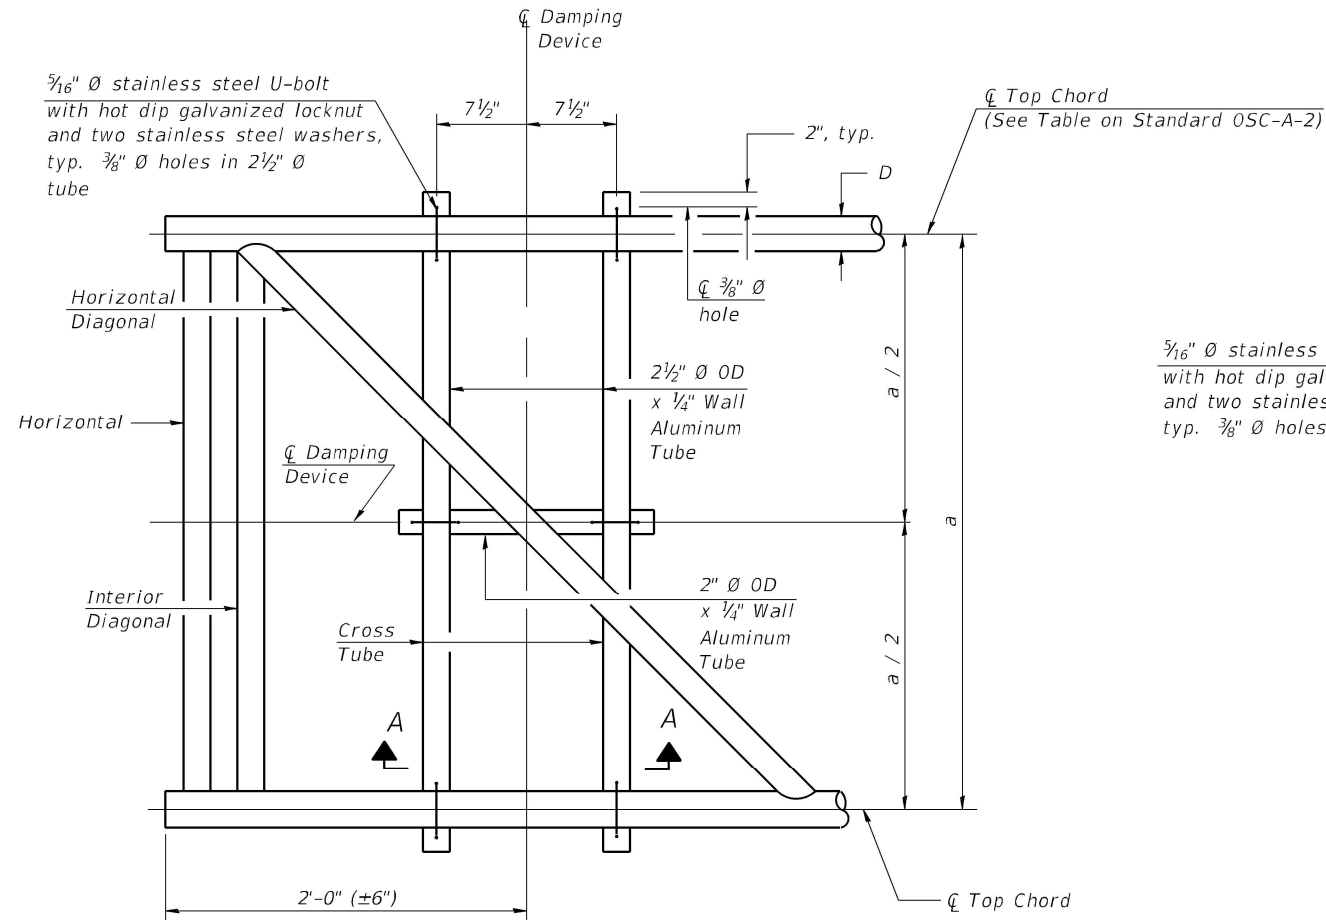

PLAN DETAIL

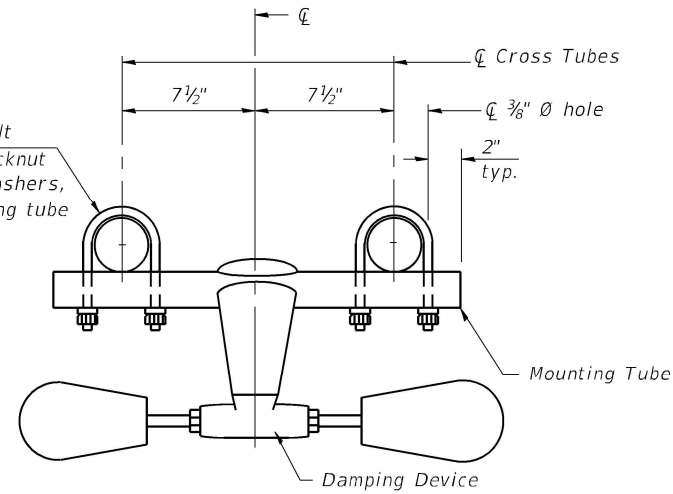


TRUSS DAMPING
DEVICE CONNECTION DETAIL

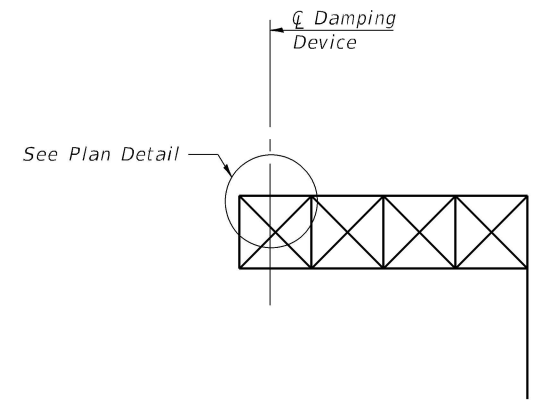


ELEVATION
Aluminum Cantilever
Sign Structure

GENERAL NOTES

- Damper: One damper per truss. (31 lbs. Stockbridge-Type Aluminum-29" minimum between ends of weights)
- Materials: Aluminum tubes shall be ASTM B221 alloy 6061 temper T6

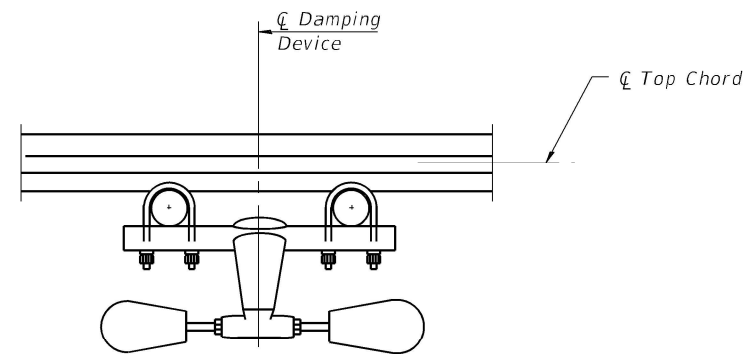

SECTION A-A

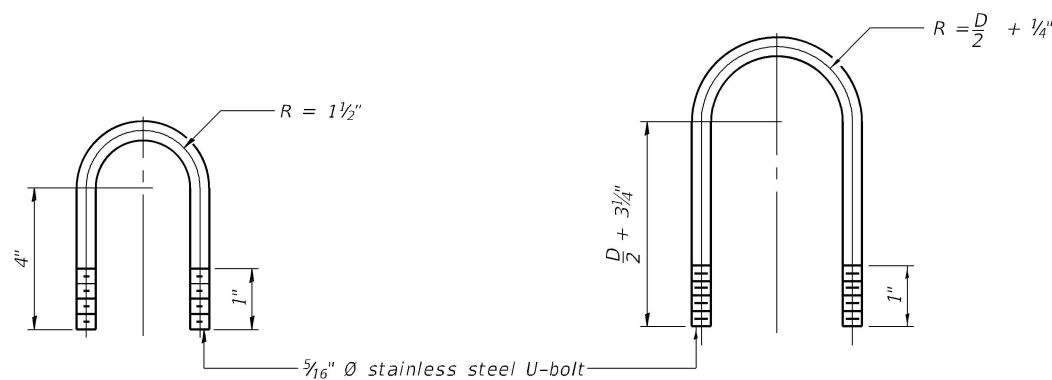

DAMPING DEVICE MOUNTING
TUBE U-BOLT DETAIL
(Typical)

TOP CHORD TO CROSS TUBE
U-BOLT DETAIL
(Typical)

OSC-A-D

5-15-2023

TranSmart
100 S. Wacker Drive Suite 400
Chicago, Illinois 60606

USER NAME = dmeier	DESIGNED - ZC	REVISED -
PLOT SCALE = 2.0000 ' / in.	DRAWN - JDK	REVISED -
PLOT DATE = 1/24/2025	CHECKED - AS	REVISED -
	DATE -	REVISED -

STATE OF ILLINOIS
DEPARTMENT OF TRANSPORTATION

CANTILEVER SIGN STRUCTURE-DAMPING DEVICE
IL 64 (NORTH AVE) SMART CORRIDOR

SCALE: N.T.S. SHEET 6 OF 6 SHEETS STA. N/A TO STA. N/A

F.A.P. RTE.	SECTION	COUNTY	TOTAL SHEETS	SHEET NO.
307	2020-263-SUR,SW&TS	DUPAGE	529	500
CONTRACT NO. 62N33				
ILLINOIS FED. AID PROJECT				