
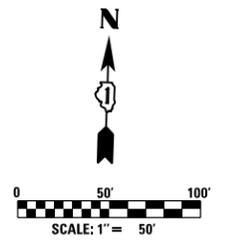


**NOTES:**

1. SEE DRAWING E-1 FOR ELECTRICAL SYMBOL LIST AND ABBREVIATIONS. SEE DRAWING E-2 FOR ELECTRICAL GENERAL NOTES.
2. CONTRACTOR MUST ROUTE CONDUIT FROM A LOCATION SPECIFIED BY COMED TO THE PRIMARY SIDE OF THE PROPOSED SERVICE TRANSFORMER. CONDUIT MATERIAL AND SIZE TO BE DETERMINED BY COMED, AND PAID FOR UNDER THE "ELECTRIC UTILITY SERVICE CONNECTION" PAY ITEM. SEPARATE PAYMENT WILL NOT BE MADE.

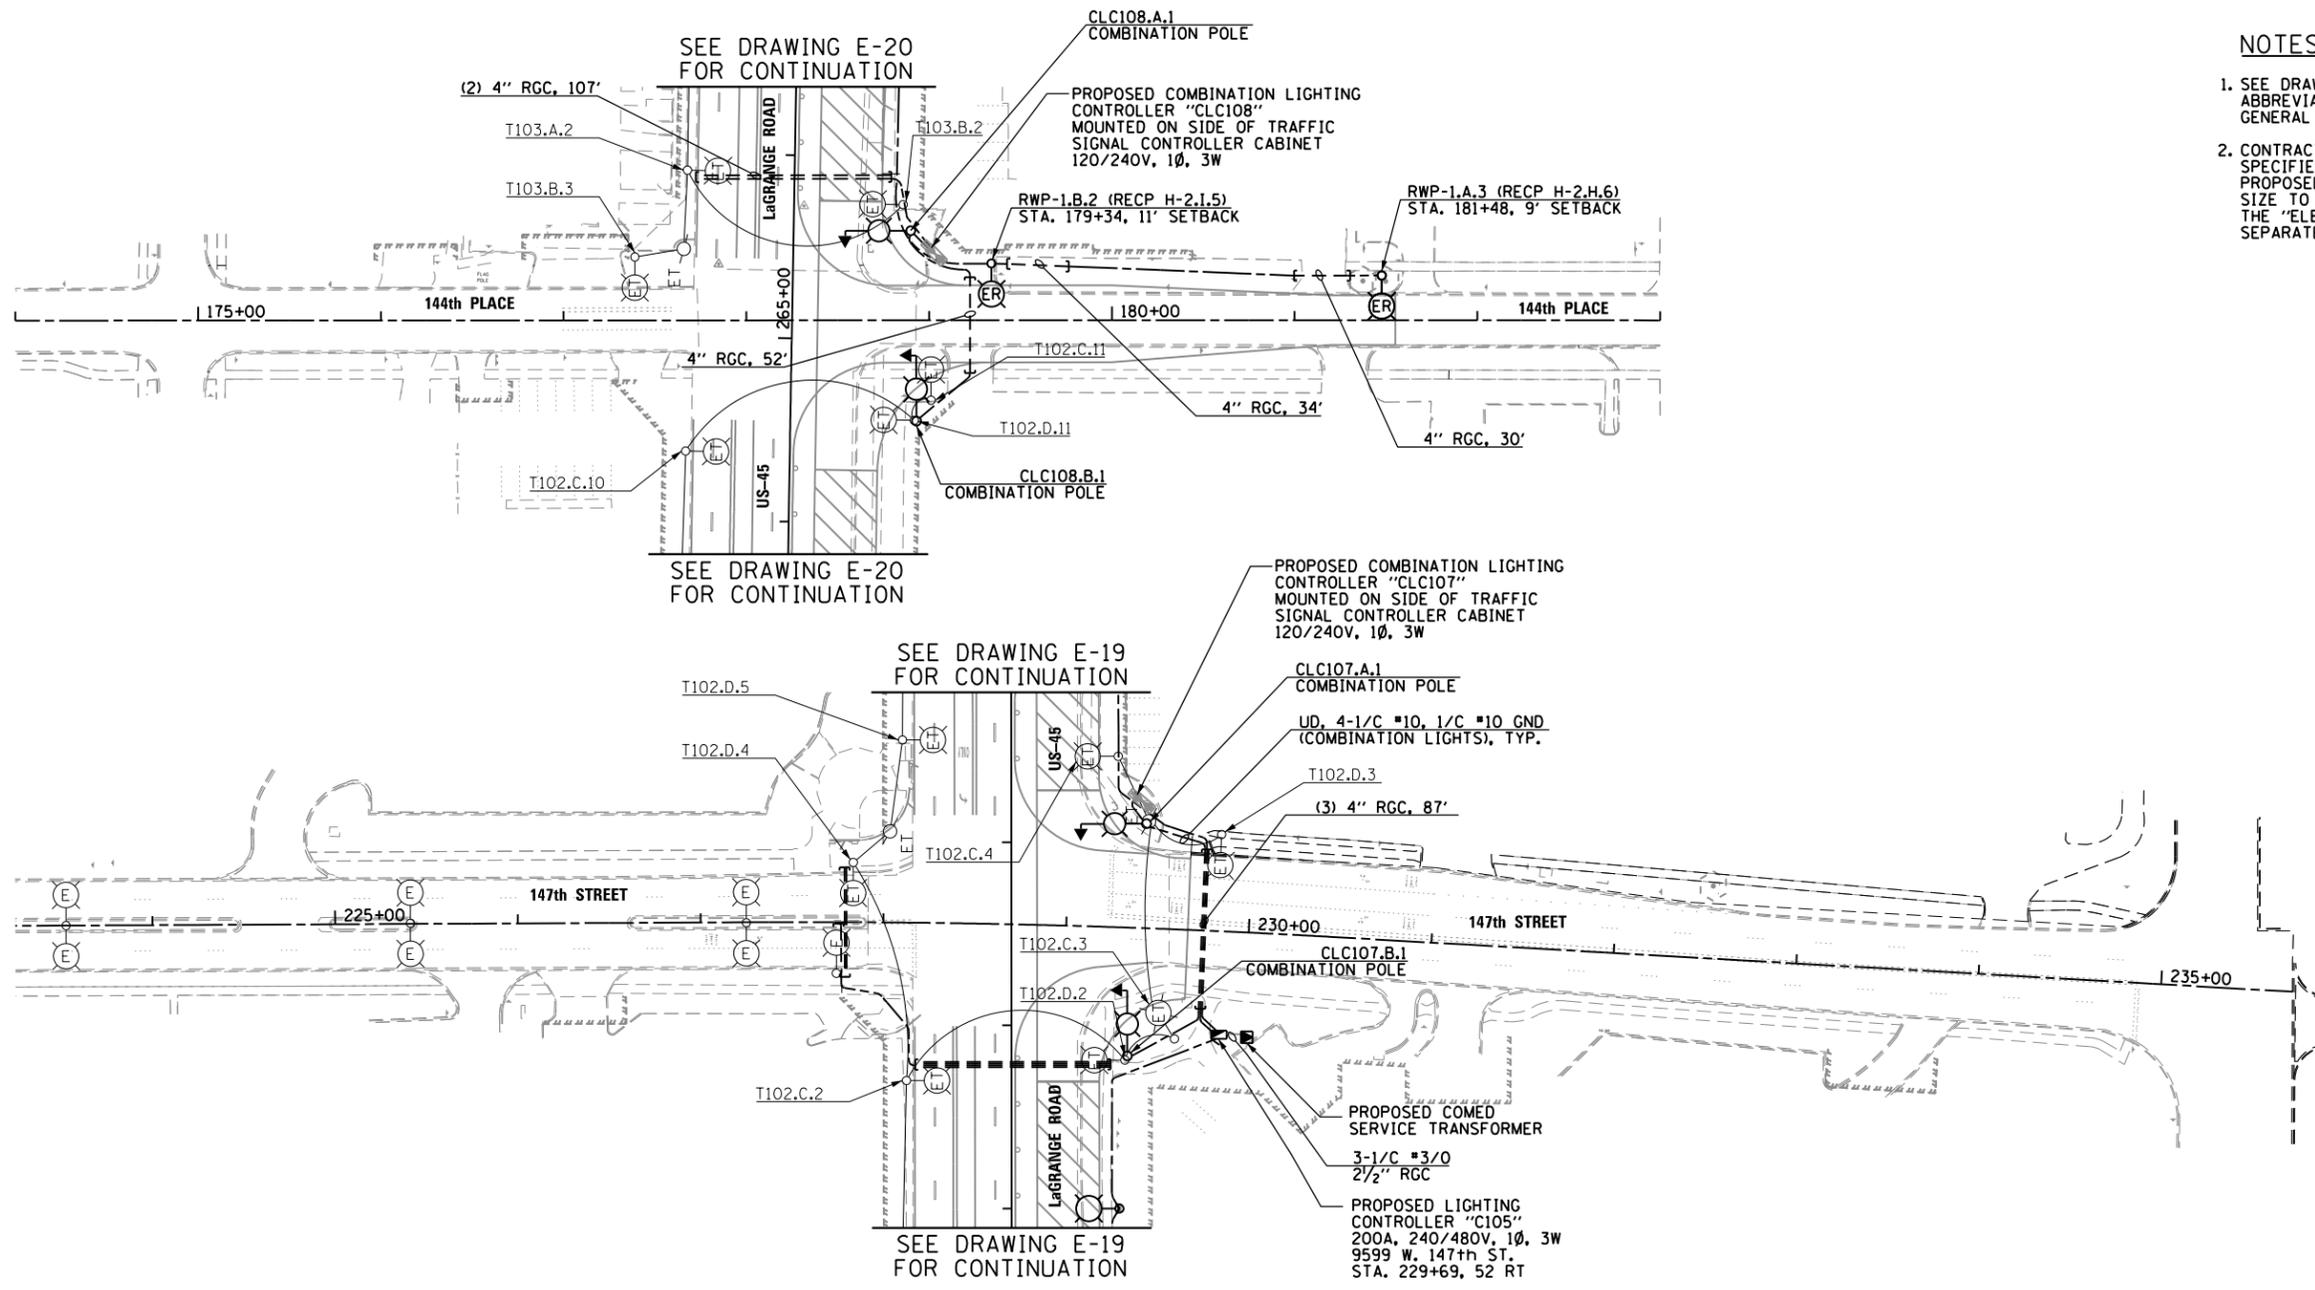

100 S. WACKER DR.  
 SUITE 600  
 CHICAGO, IL 60606  
 TEL (312) 935-1000  
 FAX (312) 935-4198  
**URS**

FILE NAME =	USER NAME =	DESIGNED -	REVISED -
D160M61-SHT-E23.dgn	michal_bartusiewicz	MAE	
		DRAWN -	REVISED -
		MAE	
		CHECKED -	REVISED -
		DAD	
		DATE -	REVISED -
		03/13/2013	

**STATE OF ILLINOIS**  
**DEPARTMENT OF TRANSPORTATION**

**147th STREET & 144th PLACE**  
**TEMPORARY ROADWAY LIGHTING PLAN - STAGE 1A**  
 SCALE: 1"=50' SHEET 7 OF 7 SHEETS STA. VARIES TO STA. VARIES

F.A.P. RTE.	SECTION	COUNTY	TOTAL SHEETS	SHEET NO.
330	103R-4	COOK	877	434
<b>E-23</b>			CONTRACT NO. 60M61	
ILLINOIS FED. AID PROJECT				

D160M61-SHT-E23.dgn 3/15/2013 2:27:12 PM