
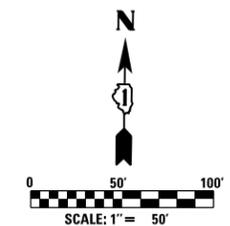


**NOTES:**

1. SEE DRAWING E-1 FOR ELECTRICAL SYMBOL LIST AND ABBREVIATIONS. SEE DRAWING E-2 FOR ELECTRICAL GENERAL NOTES.
2. CONTRACTOR SHALL REMOVE THE IDENTIFIED TEMPORARY LIGHTING UNITS, TEMPORARY LIGHTING CONTROLLERS, ALL ASSOCIATED UTILITY SERVICE WORK, AND THE TEMPORARY WIRING DURING CONSTRUCTION STAGE 2, ONCE ALL OF THE PROPOSED ROADWAY LIGHTING UNITS ALONG THE EAST SIDE OF LAGRANGE ROAD ARE INSTALLED, ENERGIZED, TESTED, AND APPROVED BY THE ENGINEER.

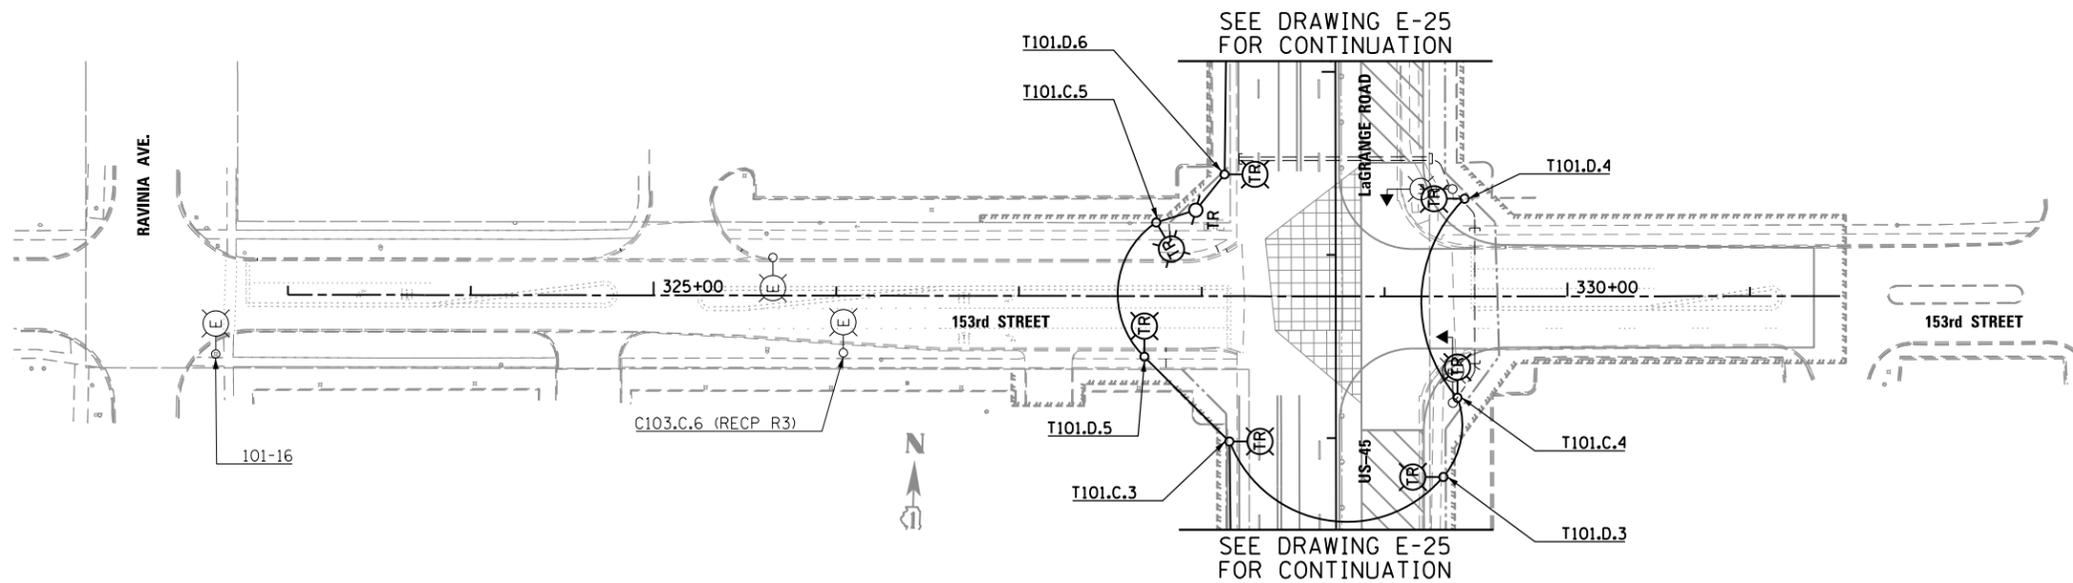

100 S. WACKER DR.  
 5TH FLOOR  
 CHICAGO, IL 60606  
 TEL (312) 935-1000  
 FAX (312) 935-4198  
**URS**

FILE NAME =	USER NAME =	DESIGNED -	REVISED -
D160M61-SHT-E28.dgn	michal_bar_tusiewicz	MAE	
		DRAWN -	REVISED -
		MAE	
		CHECKED -	REVISED -
		DAD	
SHT.PLAN	PLOT DATE =	DATE -	REVISED -
	3/15/2013	03/13/2013	

**STATE OF ILLINOIS**  
**DEPARTMENT OF TRANSPORTATION**

**153rd STREET & 149th STREET**  
**TEMPORARY ROADWAY LIGHTING PLAN - STAGE 1B**

SCALE: 1"=50' SHEET 5 OF 7 SHEETS STA. VARIES TO STA. VARIES

F.A.P. RTE.	SECTION	COUNTY	TOTAL SHEETS	SHEET NO.
330	103R-4	COOK	877	439
<b>E-28</b>			<b>CONTRACT NO. 60M61</b>	
ILLINOIS FED. AID PROJECT				