

CONSTRUCTION PLANS


INSTALL RUNWAY END IDENTIFIER LIGHTS ON RUNWAY 13 END

MARSHALL COUNTY AIRPORT BOARD
MARSHALL COUNTY AIRPORT (C75)
LACON, MARSHALL COUNTY, ILLINOIS


IDA PROJECT NO. C75-5140
SBGP PROJECT NO. 3-17-SBGP-TBD

SEPTEMBER 13, 2024 - 100% SUBMITTAL

VICINITY MAP

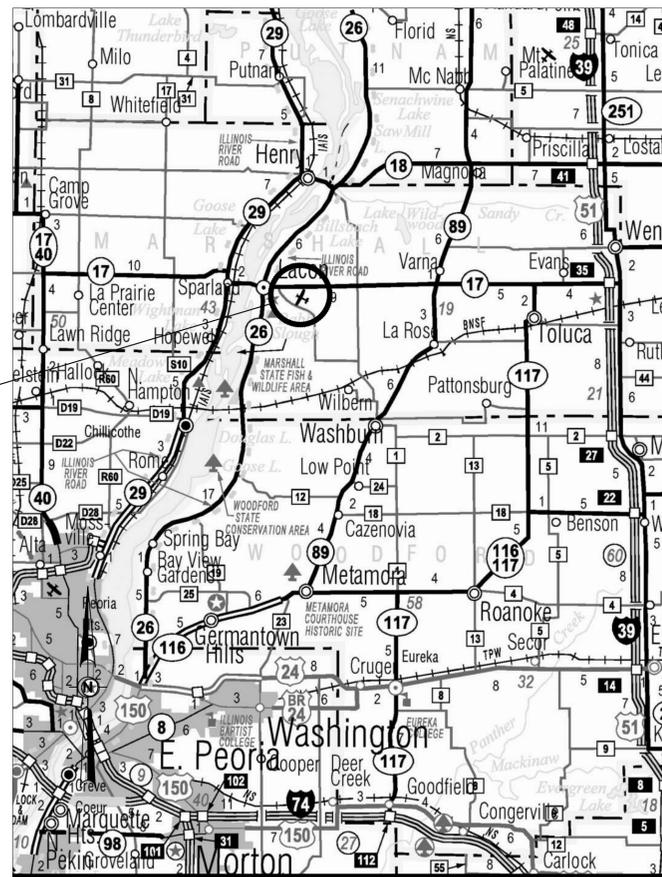

LOCATION MAP

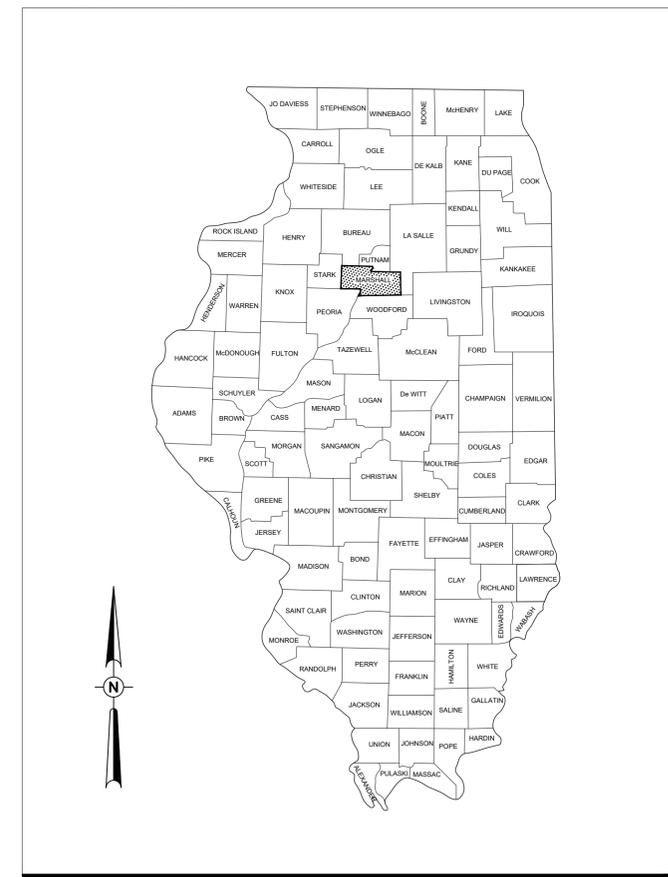

NOTICE TO CONTRACTORS AND BIDDERS

THESE CONSTRUCTION PLANS RELY UPON THE SPECIAL PROVISIONS AND THE SPECIFICATIONS TO PROVIDE FOR A COMPLETE DESCRIPTION OF THE WORK AND CONSTRUCTION REQUIREMENTS. THE PLANS SHALL ONLY BE USED IN COMBINATION WITH ALL CONTRACT DOCUMENTS.

No.	Issue/Description	Sheets Changed	Date	By

COVERING ELECTRICAL DESIGN

Kevin N. Lightfoot
9/13/2024
EXPIRES: 11/30/2025



Kevin N. Lightfoot, P.E.
Senior Electrical Engineer

SEPTEMBER 13, 2024
Date

PLANS PREPARED BY:



HANSON PROFESSIONAL SERVICES INC.
1525 South Sixth Street
Springfield, Illinois 62703-2883
Telephone: 217.788.2450
Fax: 217.788.2503



Lindsay Hausman
Lindsay D. Hausman, P.E.
Project Engineer

SEPTEMBER 13, 2024
Date



MARSHALL COUNTY AIRPORT BOARD
1315 ILLINOIS 17
Lacon, Illinois 61540

Joe Troglio
Joe Troglio
Airport Manager

SEPTEMBER 13, 2024
Date



SHEET LIST TABLE	
Sheet Number	Sheet Title
1	COVER SHEET
2	SUMMARY OF QUANTITIES & GENERAL NOTES
3	SITE AND SAFETY PLAN
4	SITE AND SAFETY PLAN DETAILS
5	EXISTING ELECTRICAL RUNWAY 13 END REILS
6	PROPOSED ELECTRICAL RUNWAY 13 END REILS
7	REIL DETAILS AND NOTES
8	AIRFIELD LIGHTING CABLE SPLICE DETAILS
9	CONDUIT TRENCH DETAIL
10	CABLE AND DUCT MARKER DETAILS
11	SPLICE CAN DETAIL
12	ELECTRICAL NOTES SHEET 1
13	ELECTRICAL NOTES SHEET 2
14	GROUNDING DETAILS
15	GROUND RESISTANCE TESTING DETAILS
16	GROUNDING NOTES
17	ELECTRICAL LEGEND AND ABBREVIATIONS
18	EXISTING ELECTRICAL ONE-LINE FOR VAULT AND AIRFIELD
19	EXISTING ELECTRICAL ONE-LINE FOR RWY 13 REILS AND OTHER NAVAIDS
20	PROPOSED ELECTRICAL ONE-LINE FOR RWY 13 REILS
21	EXISTING HIGH VOLTAGE WIRING SCHEMATICS FOR RWY 13-31 AND TWY C
22	SERIES CIRCUIT CABLE TESTING DETAILS
23	LEGEND PLATE SCHEDULES

SUMMARY OF QUANTITIES - BASE BID				
ITEM NO.	DESCRIPTION	UNIT	TOTAL QUANTITY	AS-BUILT QUANTITY
AR125565	SPLICE CAN	EACH	1	
AR125610	REILS	PAIR	1	
AR125907	REMOVE REILS	PAIR	1	
AR150520	MOBILIZATION	L SUM	1	
AR800564	CABLE AND CCR TESTING AND CALIBRATION	L SUM	1	

GENERAL NOTES

- THE PROJECT PAY ITEMS ARE INTENDED TO BE INCLUSIVE OF ALL WORK TO BE PERFORMED AS SHOWN IN THESE PLANS. ALL INCIDENTAL WORK REQUIRED TO COMPLETE THE PROJECT TO THE SATISFACTION OF THE RESIDENT ENGINEER IS TO BE INCLUDED IN THE COSTS OF PERFORMING THESE ITEMS. THE CONTRACTOR SHALL FURNISH ALL LABOR, MATERIAL, EQUIPMENT, AND TRANSPORTATION NECESSARY TO CONSTRUCT ALL ELEMENTS OF THE PROJECT AS DESCRIBED IN THE CONSTRUCTION PLANS AND SPECIFICATIONS.
- THE RULES, REGULATIONS, AND SPECIFICATIONS ENUMERATED HEREIN SHALL BE CONSIDERED AS MINIMUM REQUIREMENTS. THEY SHALL NOT PROHIBIT THE CONTRACTOR FROM FURNISHING AND INSTALLING HIGHER GRADES OF MATERIAL THAN ARE SPECIFIED HEREIN, IF APPROVED BY THE ENGINEER.
- ACCESS TO THE SITE SHALL BE RESTRICTED EXCLUSIVELY TO THE DESIGNATED CONSTRUCTION ENTRANCE, STAGING AREA, AND HAUL ROUTE. NO EQUIPMENT OR PERSONNEL SHALL BE PERMITTED OUTSIDE THE GENERAL PROJECT AREA.
- IT SHALL BE THE RESPONSIBILITY OF THE CONTRACTOR TO PROTECT AND KEEP CLEAN OF DEBRIS ALL EXISTING AIRFIELD AND ROADWAY PAVEMENTS AT ALL TIMES. ANY DAMAGE TO EXISTING ELECTRICAL, DRAINAGE, AND PAVEMENT STRUCTURES SHALL BE IMMEDIATELY REPAIRED AT NO ADDITIONAL COST TO THE CONTRACT.
- CONTRACTOR IS REQUIRED TO PROVIDE THEIR OWN RESTROOM FACILITIES.
- THE LOCATION OF THE ENGINEER'S FIELD OFFICE WILL BE DETERMINED AT THE PRE-CONSTRUCTION MEETING.
- THE OWNER SHALL HAVE THE RIGHT OF FIRST REFUSAL FOR ALL SALVAGEABLE MATERIAL REMOVED ON THE PROJECT.
- THE CONTRACTOR SHALL BE RESPONSIBLE FOR OBTAINING PERMITS FOR HAULING ON PUBLIC ROADS, AS APPLICABLE. THE CONTRACTOR SHALL BE RESPONSIBLE FOR CORRECTING ANY DAMAGES TO ANY PAVEMENTS (PUBLIC OR PRIVATE) CAUSED BY HIS/HER CONSTRUCTION EQUIPMENT OR PERSONNEL.
- THE CONTRACTOR SHALL PROVIDE ONE SET OF PRELIMINARY REDLINED RECORD DRAWINGS TO THE RESIDENT ENGINEER AT THE COMPLETION OF THE PROJECT FOR INCORPORATION INTO THE OFFICIAL RECORD DRAWINGS HE WILL PREPARE.
- APPROXIMATE LOCATIONS OF UNDERGROUND UTILITIES ARE SHOWN THROUGHOUT THESE PLANS. THE CONTRACTOR SHALL DETERMINE EXACT LOCATIONS AND PROTECT THESE UTILITIES DURING CONSTRUCTION. ANY UTILITIES DAMAGED DURING CONSTRUCTION SHALL BE REPAIRED AT THE CONTRACTOR'S EXPENSE. CONTRACTOR SHALL COORDINATE WITH THE PROPER AUTHORITIES FOR THE PURPOSE OF LOCATING AND PROTECTING EXISTING UNDERGROUND UTILITIES.
- NPDES PERMIT - THIS PROJECT WILL NOT DISTURB MORE THAN 1 ACRE, THEREFORE A NPDES PERMIT IS NOT REQUIRED.
- MATERIAL CERTIFICATIONS - MATERIALS CANNOT BE INSTALLED UNTIL ALL THE MATERIAL CERTIFICATIONS FOR THAT ITEM HAVE BEEN RECEIVED, REVIEWED AND ACCEPTED BY THE RESIDENT ENGINEER. MATERIALS INSTALLED WITHOUT APPROVAL ARE SUBJECT TO REMOVAL AND REPLACEMENT AT THE CONTRACTOR'S EXPENSE.
- CERTIFIED PAYROLLS - THE RESIDENT ENGINEER CANNOT FORWARD A CONSTRUCTION REPORT FOR PAYMENT TO THE IDOT-DIVISION OF AERONAUTICS FOR PROCESSING UNTIL ALL CERTIFIED PAYROLLS FOR THAT PERIOD HAVE BEEN RECEIVED.

RESPONSIBILITY FOR EXISTING UTILITIES

THE LOCATION, SIZE AND/OR TYPE OF MATERIAL OF EXISTING UNDERGROUND OR OVERHEAD UTILITIES AS MAY BE INDICATED ON THESE CONSTRUCTION PLANS IS NOT REPRESENTED AS BEING ACCURATE, SUFFICIENT OR COMPLETE. NEITHER THE OWNER NOR THE PROJECT ENGINEER HAVE INDEPENDENTLY VERIFIED THIS INFORMATION AND NEITHER ASSUMES ANY RESPONSIBILITY WHATSOEVER IN RESPECT TO THE ACCURACY, SUFFICIENCY OR COMPLETENESS OF THE INFORMATION AND GIVE NO EXPRESSED OR IMPLIED GUARANTEE THAT ANY CONDITIONS INDICATED ARE REPRESENTATIVE OF ACTUAL CONDITIONS TO BE ENCOUNTERED.

IT SHALL BE THE CONTRACTOR'S RESPONSIBILITY TO DETERMINE THE ACTUAL LOCATION OF ALL SUCH FACILITIES, INCLUDING SERVICE CONNECTIONS TO UNDERGROUND UTILITIES. PRIOR TO CONSTRUCTION, THE CONTRACTOR SHALL NOTIFY ALL UTILITY COMPANIES AND AGENCIES OF HIS CONSTRUCTION PLANS AND SHALL OBTAIN FROM EACH PARTY DETAILED INFORMATION AND ASSISTANCE RELATIVE TO THE LOCATION OF ALL UTILITIES AND THE WORKING SCHEDULE OF ANY REMOVALS OR ADJUSTMENTS REQUIRED OF THE UTILITY. THE CONTRACTOR SHALL CONTACT J.U.L.I.E. (PHONE 800-892-0123) TO ASSIST IN THE ABOVE.

THE CONTRACTOR SHALL PROTECT ANY FACILITIES TO THE SATISFACTION OF THE UTILITY OR OWNING-AGENCY WITH THE COST OF ANY REQUIRED PROTECTION TO BE INCIDENTAL TO THE CONTRACT. IN THE EVENT A UTILITY LINE OR SERVICE IS UNEXPECTEDLY ENCOUNTERED DURING CONSTRUCTION, THE CONTRACTOR SHALL IMMEDIATELY NOTIFY THE OWNER'S REPRESENTATIVE AND THE UTILITY COMPANY OR AGENCY OF JURISDICTION. ANY SUCH UTILITIES DISTURBED BY THE CONTRACTOR'S OPERATIONS SHALL BE RESTORED TO SERVICE AT ONCE.

J.U.L.I.E. INFORMATION

COUNTY _____ MARSHALL
 CITY _____ LACON
 TOWNSHIP _____ 30N
 RANGE _____ 2W
 SECTION NO. _____ 31
 PRINCIPAL MERIDIAN _____ 3
 QUAD _____ LACON
 TWP./PRECINCT _____ HOPEWEL TOWNSHIP
 ADDRESS _____ MARSHALL COUNTY COURT AIRPORT
 1315 IL-17
 LACON, IL 61540

INSTALL RUNWAY END IDENTIFIER LIGHTS ON RUNWAY END 13

SBG: 3-17-SBGP-TBD

IDA No: C75-5140


Contract No. MA035

NO.	DATE	DESCRIPTION		
		DES	DWN	REV

ISSUE: AUGUST, 16 2024
 PROJECT NO: 23A1045
 CAD FILE: G-002-SQQ.DWG
 DESIGN BY: KNL 05/19/2024
 DRAWN BY: JAP 05/02/2024
 REVIEWED BY: LDH 06/15/2024

SHEET TITLE

SUMMARY OF QUANTITIES & GENERAL NOTES

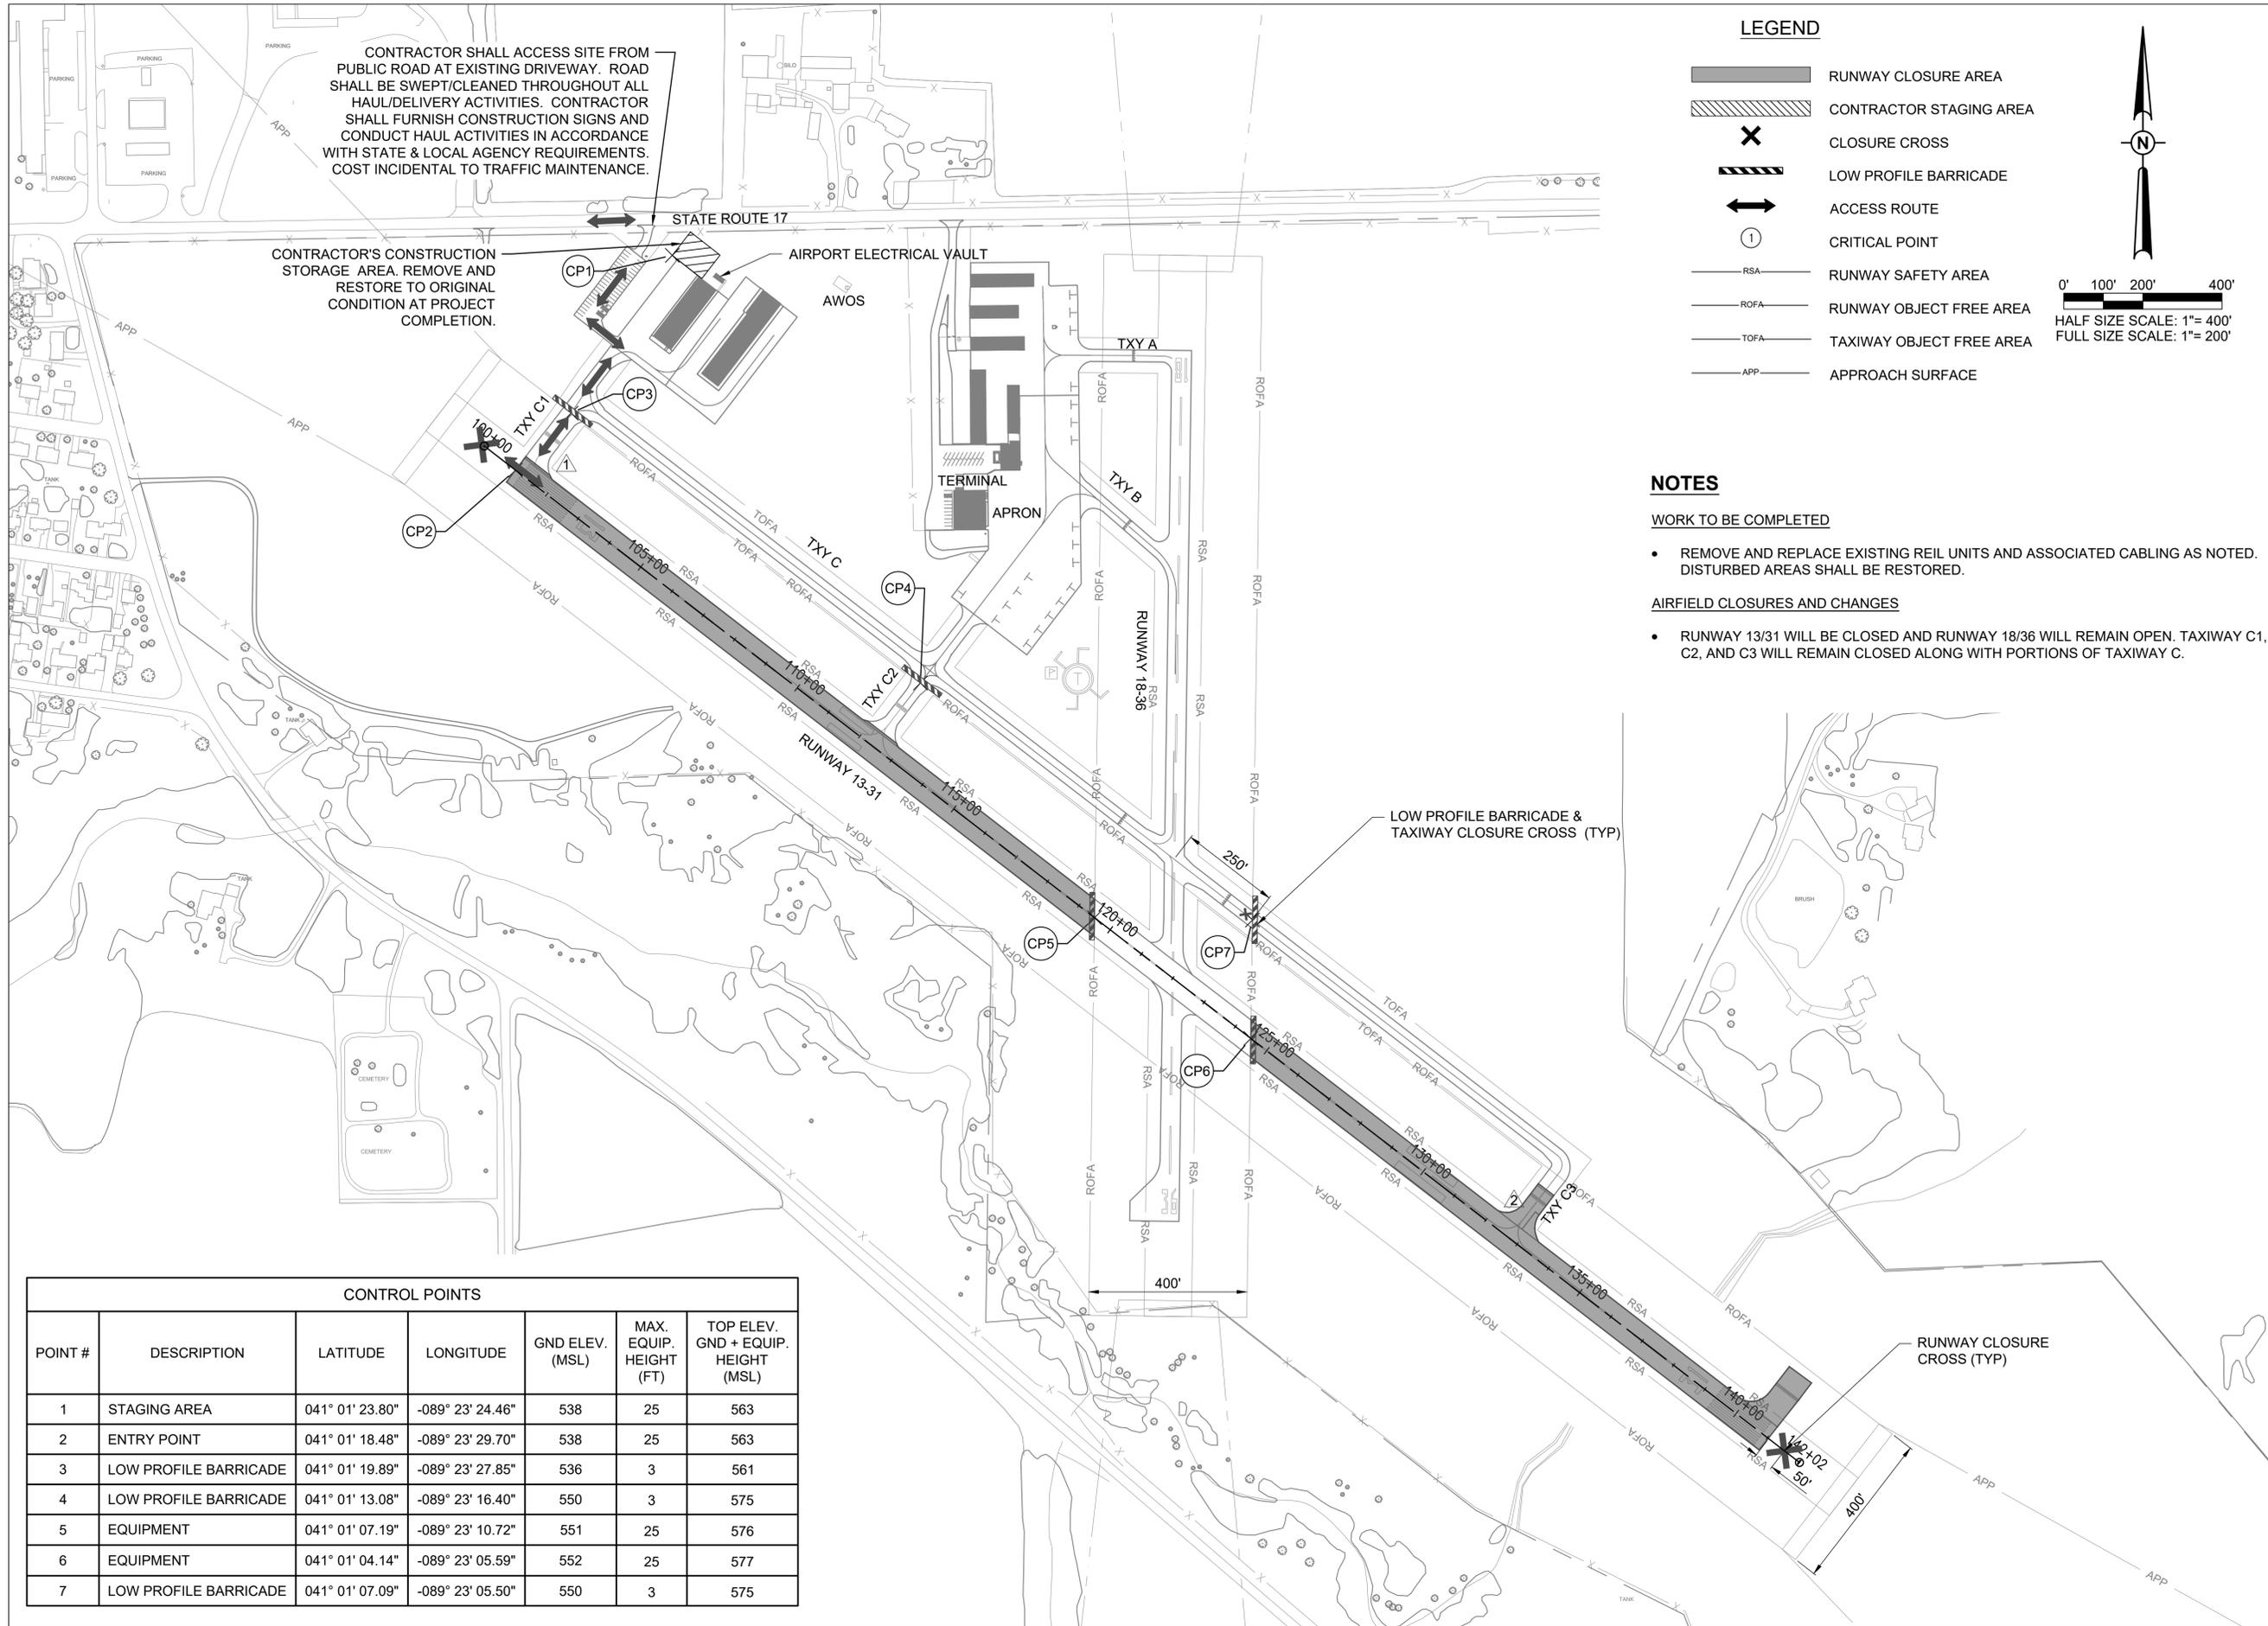

CONTRACTOR SHALL ACCESS SITE FROM PUBLIC ROAD AT EXISTING DRIVEWAY. ROAD SHALL BE SWEEP/CLEANED THROUGHOUT ALL HAUL/DELIVERY ACTIVITIES. CONTRACTOR SHALL FURNISH CONSTRUCTION SIGNS AND CONDUCT HAUL ACTIVITIES IN ACCORDANCE WITH STATE & LOCAL AGENCY REQUIREMENTS. COST INCIDENTAL TO TRAFFIC MAINTENANCE.

CONTRACTOR'S CONSTRUCTION STORAGE AREA. REMOVE AND RESTORE TO ORIGINAL CONDITION AT PROJECT COMPLETION.

LEGEND

- RUNWAY CLOSURE AREA
- CONTRACTOR STAGING AREA
- CLOSURE CROSS
- LOW PROFILE BARRICADE
- ACCESS ROUTE
- CRITICAL POINT
- RSA RUNWAY SAFETY AREA
- ROFA RUNWAY OBJECT FREE AREA
- TOFA TAXIWAY OBJECT FREE AREA
- APP APPROACH SURFACE

0' 100' 200' 400'
HALF SIZE SCALE: 1"= 400'
FULL SIZE SCALE: 1"= 200'

NOTES

WORK TO BE COMPLETED

- REMOVE AND REPLACE EXISTING REIL UNITS AND ASSOCIATED CABLING AS NOTED. DISTURBED AREAS SHALL BE RESTORED.

AIRFIELD CLOSURES AND CHANGES

- RUNWAY 13/31 WILL BE CLOSED AND RUNWAY 18/36 WILL REMAIN OPEN. TAXIWAY C1, C2, AND C3 WILL REMAIN CLOSED ALONG WITH PORTIONS OF TAXIWAY C.

INSTALL RUNWAY END IDENTIFIER LIGHTS ON RUNWAY END 13

SBG: 3-17-SBGP-TBD

IDA No: C75-5140

Contract No. MA035

NO.	DATE	DESCRIPTION		
		DES	DWN	REV

ISSUE: AUGUST, 16 2024

PROJECT NO: 23A1045

CAD FILE: C-102-CSPP.DWG

DESIGN BY: KNL 05/19/2024

DRAWN BY: JAP 05/02/2024

REVIEWED BY: LDH 06/15/2024

SHEET TITLE

SITE AND SAFETY PLAN

CONTROL POINTS

POINT #	DESCRIPTION	LATITUDE	LONGITUDE	GND ELEV. (MSL)	MAX. EQUIP. HEIGHT (FT)	TOP ELEV. GND + EQUIP. HEIGHT (MSL)
1	STAGING AREA	041° 01' 23.80"	-089° 23' 24.46"	538	25	563
2	ENTRY POINT	041° 01' 18.48"	-089° 23' 29.70"	538	25	563
3	LOW PROFILE BARRICADE	041° 01' 19.89"	-089° 23' 27.85"	536	3	561
4	LOW PROFILE BARRICADE	041° 01' 13.08"	-089° 23' 16.40"	550	3	575
5	EQUIPMENT	041° 01' 07.19"	-089° 23' 10.72"	551	25	576
6	EQUIPMENT	041° 01' 04.14"	-089° 23' 05.59"	552	25	577
7	LOW PROFILE BARRICADE	041° 01' 07.09"	-089° 23' 05.50"	550	3	575

SEP 25, 2024 8:26 AM HALISM00682
I:\23\JOBS\23A1045_00\CAD\AIRPORT\1\SHEET\C-102-CSPP.DWG

SAFETY NOTES

- ALL PROVISIONS OF THE LATEST EDITION OF FAA ADVISORY CIRCULAR AC 150/5370-2 (CURRENT EDITION), "OPERATIONAL SAFETY ON AIRPORTS DURING CONSTRUCTION", APPLY TO THIS CONTRACT, EXCEPT AS MODIFIED BY THIS SAFETY PLAN. **ANY MODIFICATION TO THIS PLAN MUST BE APPROVED BY THE FAA, THE OWNER, AND THE RESIDENT ENGINEER/TECHNICIAN.**
- THE CONTRACTORS SHALL MINIMIZE DISRUPTION OF STANDARD OPERATING PROCEDURES FOR AERONAUTICAL ACTIVITY BY REMAINING WITHIN THE PRESCRIBED STAGING, CONSTRUCTION, AND PHASING AREAS PRESENTED ON THE CONSTRUCTION SAFETY AND PHASING PLAN SHEETS.
- NO UNAUTHORIZED PERSONNEL SHALL ENTER ANY AREA OF THE AIRPORT THAT COULD POTENTIALLY BE HAZARDOUS. THE AIRPORT MANAGER RESERVES THE RIGHT TO SUSPEND OPERATIONS IN ORDER TO MAINTAIN SAFETY AT THE AIRPORT.
- PRIOR TO ACCESSING THE AIRFIELD, ANY DESIGNATED CONTRACTOR OR SUBCONTRACTOR EMPLOYEES WHO WILL BE OPERATING OR ESCORTING A VEHICLE ON AN ACTIVE AREA OF THE AIRFIELD MUST BE FAMILIAR WITH THE "FAA GUIDE TO GROUND VEHICLE OPERATIONS", AND KEEP A HARD COPY IN THE VEHICLE FOR REFERENCE. THE GUIDE CAN BE FOUND AT: https://www.faa.gov/airports/runway_safety/media/Ground_Vehicle_Guide_Proof_Final.pdf
- NO CONSTRUCTION VEHICLES SHALL BE DRIVEN ACROSS ANY ACTIVE (OPEN) AIRFIELD PAVEMENT AREA WITHOUT AN APPROPRIATE ESCORT. CONSTRUCTION EQUIPMENT OR CONSTRUCTION ACTIVITY WILL NOT BE PERMITTED WITHIN **250'** OF RWY 13/31 AND **125'** RWY 18/36 (DISTANCES MEASURED FROM ACTIVE CENTERLINES) UNLESS CLOSED OR OTHERWISE NOTED. CONSTRUCTION EQUIPMENT OR CONSTRUCTION ACTIVITY WILL ALSO NOT BE PERMITTED WITHIN WITHIN **66.5'** OF ANY ACTIVE AIRPORT TAXIWAY CENTERLINE OR APRON UNLESS OTHERWISE NOTED.
- CONTRACTOR EQUIPMENT, VEHICLES, AND PROJECT MATERIALS SHALL BE STORED AT THE STAGING AREA SHOWN ON THE PLAN VIEW, EXCEPT AS OTHERWISE PROVIDED FOR AT THE PRE-CONSTRUCTION CONFERENCE.
- ALL CONSTRUCTION EQUIPMENT OPERATING IN THE PRESCRIBED CONSTRUCTION AREA IS REQUIRED TO DISPLAY A CHECKERBOARD FLAG PROPERLY LOCATED OR A ROTATING BEACON (STROBE) AS SPECIFIED IN AC 150/5210-5, "PAINTING, MARKING, AND LIGHTING OF VEHICLES USED ON AN AIRPORT" LATEST EDITION.
- NO CONSTRUCTION MATERIAL STOCKPILES SHALL BE LOCATED WITHIN **250'** OF ANY ACTIVE RUNWAY, WITHIN **66.5'** OF ANY OTHER ACTIVE AIRPORT OPERATIONS AREA, OR PENETRATE A PART 77 IMAGINARY SURFACE (PROVIDED BY THE RESIDENT ENGINEER/TECHNICIAN) EXTENDING OUT AND UPWARDS FROM ALL SIDES OF AN ACTIVE RUNWAY.
- CLOSED AIRFIELD PHASING AREAS, OPEN TRENCHES, AND STOCKPILED MATERIALS AT THE CONSTRUCTION SITE SHALL BE PROMINENTLY MARKED WITH LIGHTED BARRICADES WITH STEADY BURNING OR FLASHING RED LIGHTS AS SPECIFIED IN 150/5370-2, "OPERATIONAL SAFETY ON AIRPORT DURING CONSTRUCTION", LATEST EDITION. LIGHTED BARRICADES MUST BE NO TALLER THAN 18" (EXCLUSIVE OF SUPPLEMENTARY LIGHTS AND FLAGS) ON THE TAXIWAYS AND COMPLY WITH ADVISORY CIRCULAR 150/5370-2, LATEST EDITION. CONTRACTOR SHALL NIGHT CHECK BARRICADES DAILY FOR PROPER OPERATION.
- OPEN TRENCHES, EXCAVATIONS, AND STOCKPILED MATERIALS AT THE CONSTRUCTION SITE SHOULD BE PROMINENTLY MARKED WITH ORANGE FLAGS AND LIGHTED WITH FLASHING RED LIGHTS DURING HOURS OF RESTRICTED VISIBILITY AND/OR DARKNESS.
- NO CONSTRUCTION EQUIPMENT GREATER THAN 25' TALL WILL BE PERMITTED ON THE AIRPORT WITHOUT THE APPROVAL OF THE AIRPORT MANAGER AND ADDITIONAL AIRSPACE APPROVAL BY THE FAA. AIRSPACE APPROVALS REQUIRE CONSIDERABLE LEAD TIME AND SHOULD BE REQUESTED WELL IN ADVANCE.
- NO OPEN FLAME WELDING OR TORCH CUTTING OPERATION IS PERMITTED UNLESS ADEQUATE FIRE AND SAFETY PRECAUTIONS ARE PROVIDED AND HAVE BEEN APPROVED BY THE AIRPORT MANAGER NO FLARE POTS ARE ALLOWED ON THE PROJECT.
- SOIL, DEBRIS, AND LOOSE MATERIAL DROPPED OR TRUCKED ONTO AIRPORT ROADS, TAXIWAYS, AND SOD SURFACES, OR WHICH CAN BE BLOWN ONTO SUCH SURFACES, SHALL BE IMMEDIATELY SWEEP, PICKED UP AND REMOVED, OR PLACED INTO CLOSED CONTAINERS. ANY DAMAGE TO AIRPORT PROPERTY SHALL BE REPAIRED IMMEDIATELY AT NO COST TO THE OWNER.
- CONTRACTOR SHALL TAKE MEASURES TO AVOID TRACKING BITUMINOUS TACK COAT ASSOCIATED WITH PAVING PROJECTS ONTO ADJACENT PAVEMENT AREAS, ESPECIALLY GROOVED RUNWAY PAVEMENTS, UNLESS SUFFICIENT PROTECTION HAS BEEN APPLIED. HEAVY TRACKING OR DAMAGE TO ADJACENT PAVEMENTS AND GROOVED SURFACES MAY BE CAUSE FOR STOPPING THE WORK UNTIL ACCEPTABLE PROTECTION OR CHANGE IN WORK METHODS HAS BEEN PROVIDED.
- EACH CONTRACTOR SHALL BE RESPONSIBLE FOR LOCATING AND MAINTAINING AIRPORT LIGHTING AND NAVIGATIONAL ELECTRICAL SYSTEMS DURING CONSTRUCTION. A CONTACT PERSON AND TELEPHONE NUMBER FOR 24 HOUR EMERGENCY IMMEDIATE REPAIR SHALL BE SUBMITTED TO THE AIRPORT MANAGER AND RESIDENT ENGINEER/TECHNICIAN. HAUL ROUTES CROSSING PAVEMENT, DRAINAGE, MISCELLANEOUS. STRUCTURES AND/OR AIRFIELD CABLES SHALL BE PROTECTED FROM DAMAGE.
- ALL AIRCRAFT AND AIRPORT OPERATIONS HAVE THE RIGHT-OF-WAY. CONTRACTOR TO YIELD TO VEHICLES AND REMAIN CLEAR AT ALL TIMES.
- CONTRACTOR SHALL PLACE, SECURE, AND MAINTAIN LIGHTED BARRICADES AND CLOSURE CROSSES WHEN A RUNWAY/TAXIWAY/APRON IS CLOSED OR AS REQUIRED BY THE PLANS AND DESIGNATED BY THE RESIDENT ENGINEER/TECHNICIAN.
- CONTRACTOR SHALL MARK HAZARDOUS AREA WITH STEADY-BURNING OR FLASHING RED LIGHTS DURING PERIODS OF LOW VISIBILITY AS REQUIRED.
- THE CONTRACTOR SHALL PERIODICALLY PERFORM ONSITE INSPECTIONS THROUGHOUT THE

DURATION OF THE PROJECT WITH THE IMMEDIATE REMEDY OF ANY DIFFERENCES, WHETHER CAUSED BY NEGLIGENCE, OVERSIGHT, OR PROJECT SCOPE CHANGE.

- CONTRACTOR SHALL MOVE MAINTENANCE OF TRAFFIC COMPONENTS AT THE WRITTEN DIRECTION OF THE RESIDENT ENGINEER/TECHNICIAN AT NO ADDITIONAL COST.
- CONTRACTOR SHALL NOT REMOVE THE BARRICADES WITHOUT THE APPROVAL BY THE RESIDENT ENGINEER/TECHNICIAN.
- CONTRACTOR SHALL MAINTAIN FLASHERS, SIGNS AND/OR BARRICADES AS REQUIRED BY THE PLANS, CITY OR COUNTY REGULATIONS OR CONTRACTOR ACTIVITIES. CONTRACTOR SHALL OBTAIN ANY AND ALL REQUIRED LOCAL PERMITS UNLESS SPECIFIED OTHERWISE.
- THE CONTRACTOR SHALL UTILIZE WATER AND/OR CHEMICALS APPROVED BY THE RESIDENT ENGINEER/TECHNICIAN AS NECESSARY TO CONTROL DUST.
- THE CONTRACTOR WILL BE RESPONSIBLE FOR IMPLEMENTING MEASURES TO CONTROL OR AVOID CREATING ATTRACTANTS TO WILDLIFE. MEASURES MAY INCLUDE CONTINUOUSLY REMOVING ANY WASTE OR LOOSE MATERIALS, PLACEMENT OF MATERIALS IN APPROPRIATE STORAGE CONTAINERS, PROPERLY MAINTAINING FENCES AND GATES TO PREVENT ACCESS, AND PREVENTING PONDING OF WATER THROUGHOUT THE SITE.
- UNLESS SPECIFIED OTHERWISE, COST FOR SAFETY, STAGING, AND TRAFFIC MAINTENANCE ITEMS IS TO BE CONSIDERED INCIDENTAL TO THE PROJECT. SEPARATE PAYMENT SHALL NOT BE MADE.
- THE CONTRACTOR SHALL HAVE THE SAFETY PLAN COMPLIANCE DOCUMENT (SPCD), AS DETAILED IN THE SPECIAL PROVISIONS, SUBMITTED AND APPROVED PRIOR TO BEING ISSUED "NOTICE TO PROCEED".
- ALL RUNWAY/TAXIWAY CLOSURES SHALL BE COORDINATED WITH AIRPORT MANAGEMENT A MINIMUM OF 7 DAYS BEFORE THE DESIRED CLOSING TIME TO ALLOW FOR THE PROPER COORDINATION. AIRPORT MANAGEMENT HAS COMPLETE AUTHORITY IN DETERMINING WHEN THE RUNWAY/TAXIWAY MAY BE CLOSED.
- RUNWAY/TAXIWAY CLOSURE PROCEDURES:
 - CONTACT THE AIRPORT MANAGEMENT OR ASSIGNED REPRESENTATIVE A MINIMUM OF 7 DAYS BEFORE THE DESIRED CLOSING TIME.
 - ISSUANCE OF NOTAM AND DEACTIVATION OF THE APPLICABLE AIRFIELD LIGHTING AND NAVAIDS BY THE AIRPORT MANAGEMENT AND/OR FAA.
 - PLACEMENT OF CROSSES AND BARRICADES.


- ONLY AT THE TIME THAT ALL OF THE ABOVE ARE COMPLETED MAY ANY CONSTRUCTION OPERATIONS BEGIN WITHIN THE RUNWAY/TAXIWAY AIR OPERATIONS AREA.

RUNWAY/TAXIWAY RE-OPENING PROCEDURES:

- ENSURE ALL PERSONNEL, EQUIPMENT AND MATERIALS ARE CLEAR OF THE AIR OPERATIONS AREA.
- INSPECT THE AREA FOR LOOSE OR TRACKED DEBRIS, PAVEMENT DROP-OFFS, AND OPEN TRENCHES.
- CONTACT AIRPORT MANAGEMENT OR REPRESENTATIVE FOR FINAL INSPECTION OF THE AREA.
- REMOVE BARRICADES AND CROSSES.
- ACTIVATION OF THE AIRFIELD LIGHTING AND NAVAIDS AND CANCELLATION OF THE NOTAM BY THE AIRPORT MANAGEMENT AND/OR FAA.

BARRICADE NOTES


- ALL CONSTRUCTION SIGNS AND TRAFFIC CONTROL DEVICES SHALL CONFORM TO THE MANUAL ON UNIFORM TRAFFIC CONTROL DEVICES INCLUDING THE ILLINOIS SUPPLEMENT (LATEST EDITION) AND THE FAA ADVISORY CIRCULARS (LATEST EDITION) UNLESS NOTED OTHERWISE. THE FAA OR MORE STRINGENT SPECIFICATIONS SHALL GOVERN.
- BARRICADES SHALL BE INTERLOCKED END TO END OVER THE LENGTH OF THE PAVEMENT WHERE PROTECTING OPEN RUNWAYS, AND SPACED END TO END A MAXIMUM OF 4 FEET IN OTHER ALL OTHER AREAS. BARRICADES ARE TO BE SET BACK FROM THE ACTIVE RUNWAY OR TAXIWAY CENTERLINE THE DISTANCE AS SHOWN ON THE PLANS.
- CONSTRUCTION RED WARNING LIGHT: THESE ARE PORTABLE, LENS DIRECTED, ENCLOSED LIGHTS. THE COLOR OF THE LIGHT EMITTED SHALL BE RED. THEY MAY BE USED IN EITHER A STEADY BURN (TYPE C) OR LOW INTENSITY FLASHING MODE (TYPE A) UNLESS NOTED OTHERWISE.
- THE LIGHTING SHALL BE MAINTAINED IN OPERATION DURING THE HOURS OF DARKNESS BETWEEN 1/2 HOUR AFTER SUNSET AND 1/2 HOUR BEFORE SUNRISE AND WHEN CONDITIONS EXIST WHICH TEND TO OBSCURE VISION.
- BARRICADES SHALL BE SECURED TO THE GROUND BY APPROVED METHODS TO PREVENT MOVEMENT BY PROP WASH, JET BLAST OR OTHER WIND CURRENTS.
- THE ONLY COLOR COMBINATION ON BARRICADES IS ORANGE AND WHITE. THE ORANGE STRIPES SHALL BE ENCAPSULATED LENS REFLECTIVE SHEETING. THE WHITE STRIPES SHALL BE EITHER ENCAPSULATED OR ENCLOSED LENS REFLECTIVE SHEETING AND MUST BE IN ACCEPTABLE CONDITION.
- COST FOR PROVIDING, PLACING, MAINTAINING, RELOCATING AND REMOVING BARRICADES IS INCIDENTAL TO THE CONTRACT.

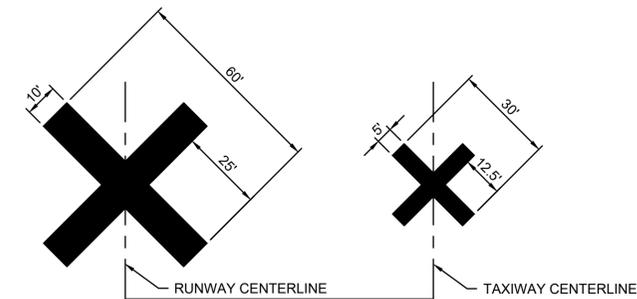

TEMPORARY CLOSURE CROSS DETAIL

NOT TO SCALE

- TEMPORARY "CLOSED RUNWAY" AND "CLOSED TAXIWAY" MARKINGS SHALL BE "AVIATION YELLOW"
- TEMPORARY "CLOSED RUNWAY" AND "CLOSED TAXIWAY" MARKINGS SHALL BE CONSTRUCTED OF PLYWOOD, DOUBLE-LAYERED SNOW FENCE OR APPROVED FABRIC AND SHALL BE SECURED TO PAVEMENT BY SANDBAGS OR OTHER APPROVED METHOD.
- TEMPORARY "CLOSED RUNWAY" MARKINGS SHALL BE PLACED OVER THE RUNWAY DESIGNATION NUMBERS UNLESS OTHERWISE DIRECTED BY THE RESIDENT ENGINEER/TECHNICIAN.
- COST FOR PROVIDING, PLACING, MAINTAINING, RELOCATING AND REMOVING "CLOSED RUNWAY" AND "CLOSED TAXIWAY" MARKINGS IS INCIDENTAL TO THE CONTRACT.

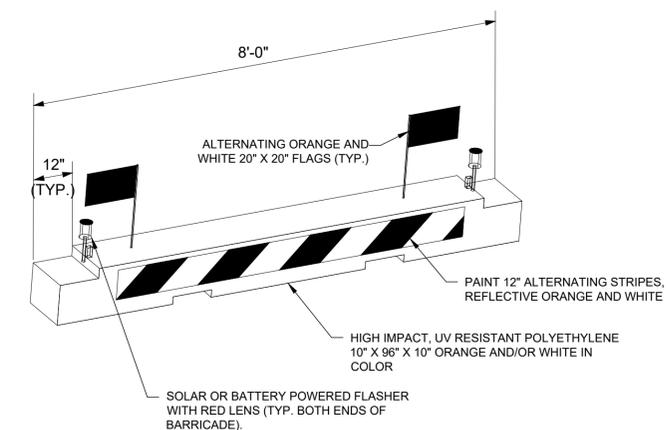

LOW PROFILE AIRCRAFT BARRICADE DETAIL

INSTALL RUNWAY END IDENTIFIER LIGHTS ON RUNWAY END 13

SBG: 3-17-SBGP-TBD

IDA No: C75-5140

Contract No. MA035

NO.	DATE	DESCRIPTION		
		DES	DWN	REV

ISSUE: AUGUST, 16 2024

PROJECT NO: 23A1045

CAD FILE: C-102-CSP-P.DWG

DESIGN BY: KNL 05/19/2024

DRAWN BY: JAP 05/02/2024

REVIEWED BY: LDH 06/15/2024

SHEET TITLE

SITE AND SAFETY PLAN DETAILS



LEGEND

 

- EXISTING PAVEMENT
- EXISTING ELECTRICAL DUCT
- EXISTING ELECTRICAL CABLES
- EXISTING UG ELECTRIC UTILITY PRIMARY
- EXISTING ELECTRICAL FEEDER
- EXISTING TELEPHONE / COMMUNICATION LINE
- EXISTING AWOS COMMUNICATION CABLE
- EXISTING STAKE MOUNTED TAXIWAY LIGHT
- EXISTING BASE MOUNTED TAXIWAY LIGHT
- EXISTING RUNWAY/TAXI GUIDANCE SIGN
- EXISTING STAKE MOUNTED RUNWAY LIGHT
- EXISTING BASE MOUNTED RUNWAY LIGHT
- EXISTING ELECTRICAL STRUCTURE (HANDHOLE, SPLICE CAN)
- EXISTING ELECTRICAL MARKER (DUCT MARKER, CABLE MARKER)
- EXISTING REIL

THE LOCATION, SIZE, AND TYPE OF MATERIAL OF EXISTING UNDERGROUND AND/OR ABOVEGROUND UTILITIES INDICATED ON THE PLANS ARE NOT REPRESENTED AS BEING ACCURATE, SUFFICIENT OR COMPLETE. NEITHER THE OWNER NOR THE ENGINEER ASSUMES ANY RESPONSIBILITY WHATSOEVER IN RESPECT TO THE ACCURACY, COMPLETENESS, OR SUFFICIENCY OF THE INFORMATION. THERE IS NO GUARANTEE, EITHER EXPRESSED OR IMPLIED, THAT THE LOCATIONS, SIZE AND TYPE OF MATERIAL OF EXISTING UNDERGROUND UTILITIES INDICATED ARE REPRESENTATIVE OF THOSE TO BE ENCOUNTERED IN THE CONSTRUCTION. IT SHALL BE THE CONTRACTOR'S RESPONSIBILITY TO DETERMINE THE ACTUAL LOCATION OF ALL SUCH FACILITIES, INCLUDING SERVICE CONNECTIONS TO UNDERGROUND UTILITIES. PRIOR TO CONSTRUCTION, THE CONTRACTOR SHALL NOTIFY THE UTILITY COMPANIES OF HIS OPERATIONAL PLANS AND SHALL OBTAIN FROM THE RESPECTIVE UTILITY COMPANIES DETAILED INFORMATION AND ASSISTANCE RELATIVE TO THE LOCATION OF THEIR FACILITIES AND THE WORKING SCHEDULE OF THE COMPANIES FOR REMOVAL OR ADJUSTMENT WHERE REQUIRED. IN THE EVENT AN UNEXPECTED UTILITY INTERFERENCE IS ENCOUNTERED DURING CONSTRUCTION, THE CONTRACTOR SHALL IMMEDIATELY NOTIFY THE UTILITY COMPANY OF JURISDICTION. THE OWNER'S REPRESENTATIVE AND/OR THE RESIDENT ENGINEER SHALL ALSO BE IMMEDIATELY NOTIFIED. ANY DAMAGE TO SUCH MAINS AND SERVICES SHALL BE RESTORED TO SERVICE AT ONCE AND PAID FOR BY THE CONTRACTOR AT NO ADDITIONAL COST TO THE CONTRACT.

ALL UTILITY CABLES AND LINES SHALL BE LOCATED BY THE RESPECTIVE UTILITY. CONTACT JULIE (JOINT UTILITY LOCATION INFORMATION FOR EXCAVATORS) FOR UTILITY INFORMATION, PHONE: 1-800-892-0123. ALSO CONTACT AIRPORT DIRECTOR/MANAGER AND AIRPORT PERSONNEL FOR ASSISTANCE IN LOCATING UNDERGROUND AIRPORT CABLES AND/OR UTILITIES. ALSO COORDINATE WORK WITH ALL ABOVEGROUND UTILITIES.

REIL REMOVAL NOTES

1. ALL WORK, POWER OUTAGES, AND/OR SHUT DOWN OF EXISTING SYSTEMS SHALL BE COORDINATED WITH THE AIRPORT MANAGER. ONCE SHUT DOWN, THE CIRCUITS SHALL BE LABELED AS SUCH TO PREVENT ACCIDENTAL ENERGIZING OF THE RESPECTIVE CIRCUITS. ALL PERSONNEL SHALL FOLLOW U.S. DEPARTMENT OF LABOR OCCUPATIONAL SAFETY & HEALTH ADMINISTRATION (OSHA) 29 CFR PART 1910 OCCUPATIONAL SAFETY & HEALTH STANDARDS FOR ELECTRICAL SAFETY AND LOCKOUT/TAGOUT PROCEDURES INCLUDING, BUT NOT LIMITED TO, 29 CFR SECTION 1910.147 THE CONTROL OF HAZARDOUS ENERGY (LOCKOUT/TAGOUT).
2. CONTRACTOR SHALL EXAMINE THE SITE TO DETERMINE THE EXTENT OF THE WORK. CONTRACTOR SHALL FIELD VERIFY EXISTING SITE CONDITIONS. CONTRACTOR SHALL FIELD VERIFY RESPECTIVE CIRCUITS AND POWER SOURCES PRIOR TO REMOVING, RELOCATING, DISCONNECTING, CONNECTING, OR WORKING ON THE RESPECTIVE AIRFIELD LIGHTING, REIL UNITS, VAULT EQUIPMENT, OR OTHER DEVICE.
3. CONTRACTOR SHALL COMPLY WITH THE REQUIREMENTS OF FAA AC NO. 150/5370-2G (OR MOST CURRENT ISSUE) "OPERATIONAL SAFETY ON AIRPORTS DURING CONSTRUCTION".
4. CONTRACTOR SHALL COMPLY WITH THE APPLICABLE REQUIREMENTS OF NFPA 70E - STANDARD FOR ELECTRICAL SAFETY IN THE WORKPLACE.
5. EXISTING REIL UNITS SHOWN TO BE REMOVED ARE TO BE REMOVED AND TURNED OVER TO THE AIRPORT. IN THE EVENT THE AIRPORT DOES NOT WANT THE REIL UNITS THEY SHALL BE DISPOSED OF OFF THE AIRPORT SITE IN A LEGAL MANNER. THE EXISTING REIL CONCRETE BASES AND L-867 BASE CANS ARE TO BE REMOVED TO THEIR FULL DEPTH AND DISPOSED OF OFF THE AIRPORT SITE IN A LEGAL MANNER. THE HOLES LEFT FROM THE REMOVAL OF REIL BASES SHALL BE FILLED IN WITH EARTH AND COMPACTED TO PREVENT FUTURE SETTLEMENT, SEEDED AND MULCHED IN ACCORDANCE WITH ITEMS 901 AND 908, RESPECTIVELY. REMOVAL OF THE EXISTING REIL UNITS WILL BE PAID FOR UNDER ITEM AR125907 REMOVE REIL PER PAIR.
6. THE EXISTING AIRFIELD LIGHTING/REILS CABLES ASSOCIATED WITH AIRFIELD LIGHTING/REILS REMOVALS SHALL BE REMOVED WHERE ACCESSIBLE AND ABANDONED IN PLACE ELSEWHERE UNLESS IT CONFLICTS WITH THE INSTALLATION OF A PROPOSED LIGHT, NAVAID, SIGN, CABLE, DUCT, PAVEMENT, OR OTHER WORK, THEN IT SHALL BE REMOVED AND DISPOSED OF OFF SITE AT NO ADDITIONAL COST TO THE CONTRACT. CONTRACTOR MAY REMOVE ABANDONED CABLES AT NO ADDITIONAL COST TO THE CONTRACT AND SHALL HAVE THE SALVAGE RIGHTS TO ABANDONED CABLES. EXPOSED CABLES AND CONDUITS ASSOCIATED WITH PLASIS'S TO BE REMOVED, SHALL BE REMOVED.
7. WHEN A RUNWAY IS CLOSED, THE NAVAIDS AND LIGHTING FOR THAT RUNWAY SHALL BE SHUT OFF.
8. NO CONNECTION TO AN ACTIVE LIGHTING CIRCUIT, NAVAID, OR OTHER CIRCUIT SHALL BE BROKEN UNTIL THE CIRCUIT HAS BEEN TURNED OFF IN ACCORDANCE WITH THE ABOVE NOTE 1.

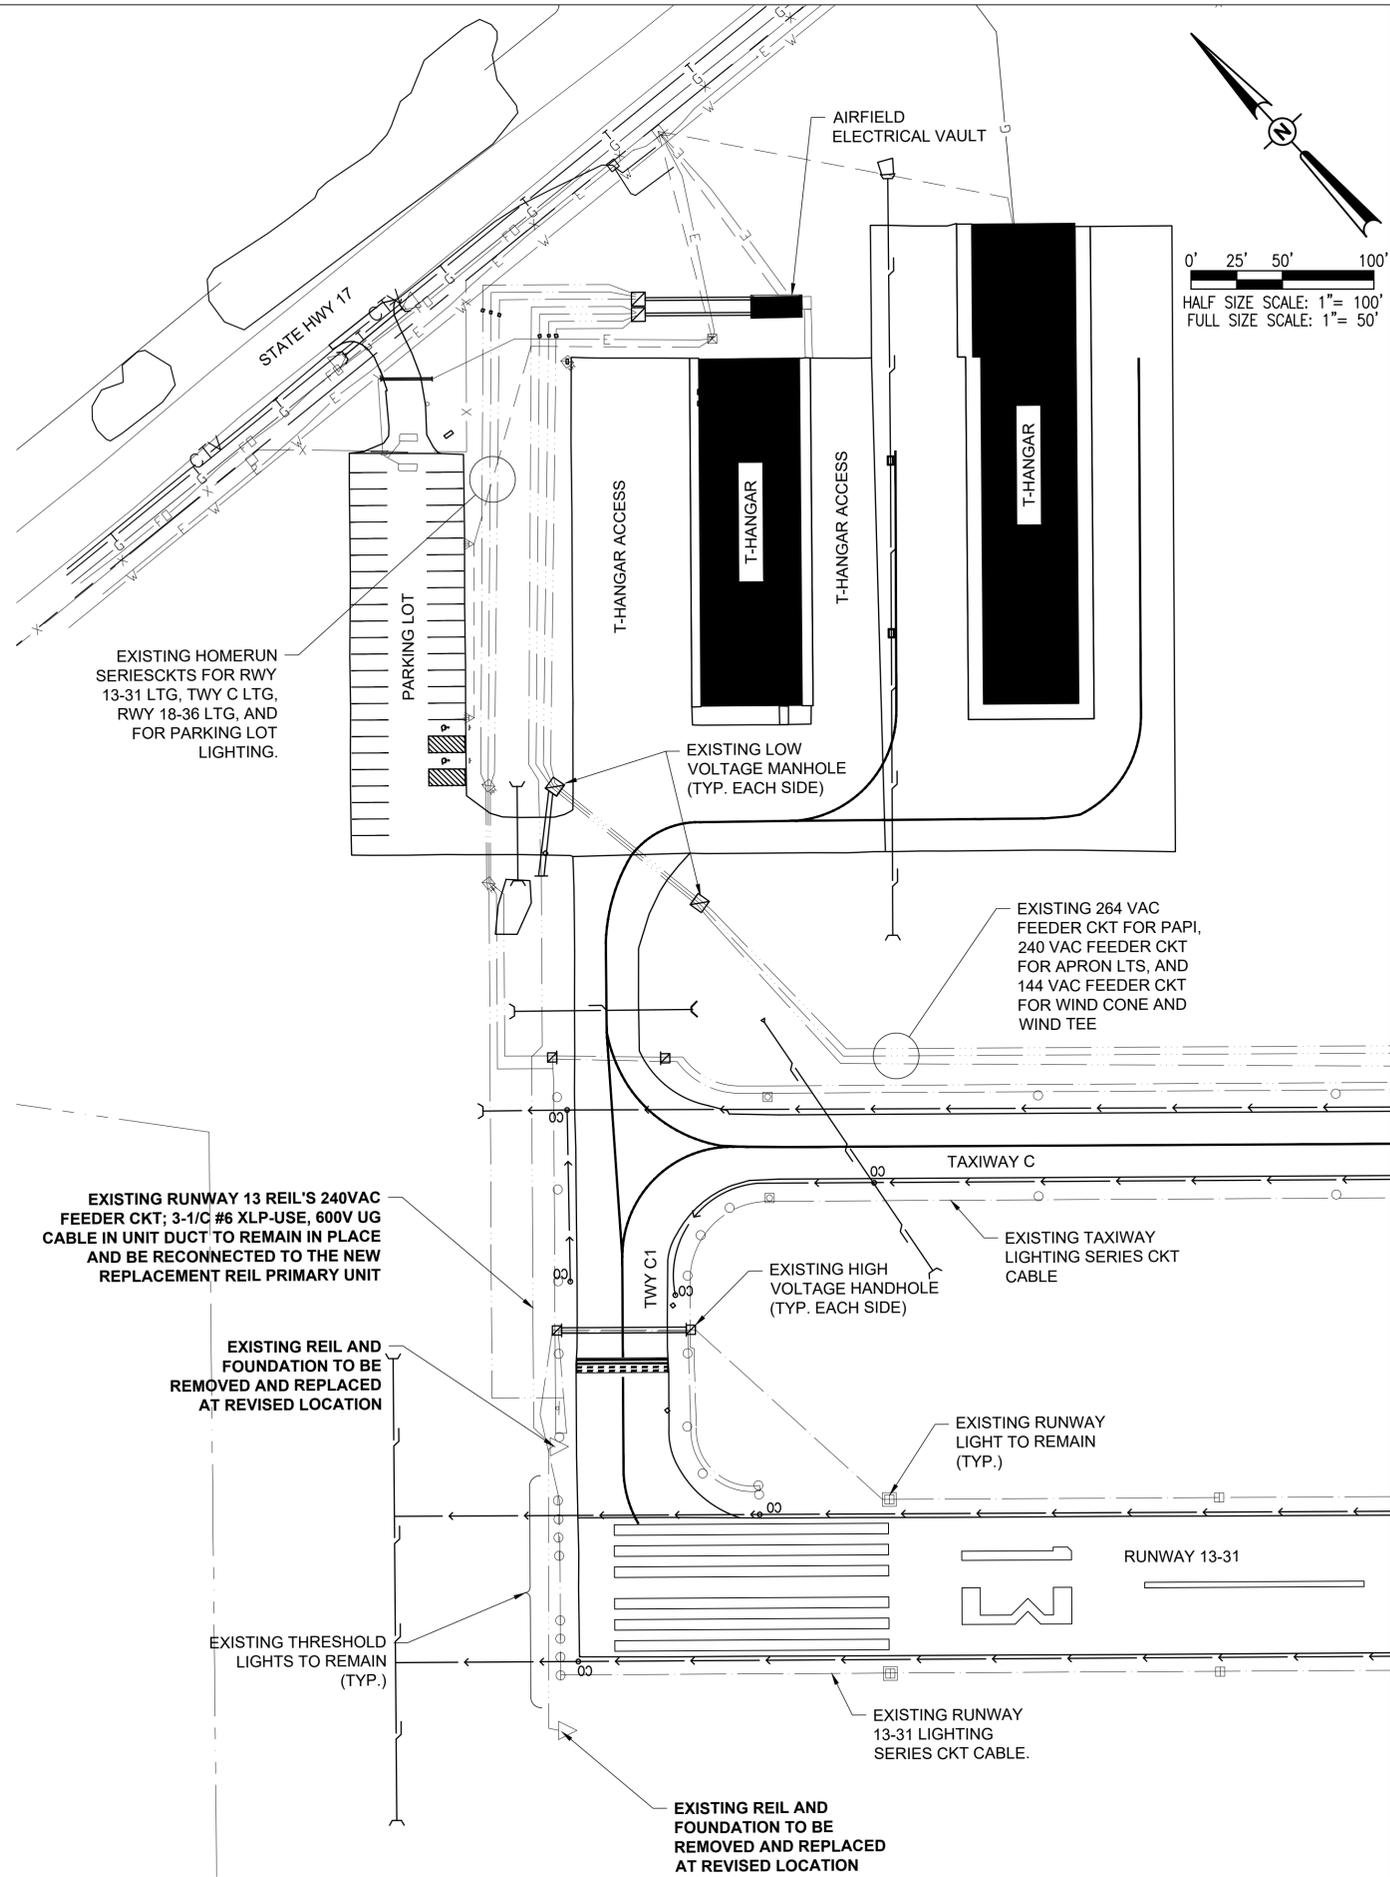

INSTALL RUNWAY END IDENTIFIER LIGHTS ON RUNWAY END 13

SBG: 3-17-SBGP-TBD

IDA No: C75-5140

Contract No. MA035

NO.	DATE	DESCRIPTION		
		DES	DWN	REV

ISSUE: AUGUST, 16 2024
PROJECT NO: 23A1045
CAD FILE: E-101-SITE.DWG
DESIGN BY: KNL 05/19/2024
DRAWN BY: JAP 05/02/2024
REVIEWED BY: KNL 6/10/2024

SHEET TITLE

EXISTING ELECTRICAL RUNWAY 13 END REILS

LEGEND

 

- EXISTING PAVEMENT
- EXISTING ELECTRICAL DUCT
- - - EXISTING ELECTRICAL CABLES
- UGE — EXISTING UG ELECTRIC UTILITY PRIMARY
- E — EXISTING ELECTRICAL FEEDER
- T — EXISTING TELEPHONE / COMMUNICATION LINE
- C — EXISTING AWOS COMMUNICATION CABLE
- EXISTING STAKE MOUNTED TAXIWAY LIGHT
- ⊠ EXISTING BASE MOUNTED TAXIWAY LIGHT
- ⊠ EXISTING RUNWAY/TAXI GUIDANCE SIGN
- ⊠ EXISTING STAKE MOUNTED RUNWAY LIGHT
- ⊠ EXISTING BASE MOUNTED RUNWAY LIGHT
- ⊠_{HH} ⊠_{SC} EXISTING ELECTRICAL STRUCTURE (HANDHOLE, SPLICE CAN)
- _{DM} □_{CM} EXISTING ELECTRICAL MARKER (DUCT MARKER, CABLE MARKER)
- ◀ PROPOSED REIL
- _{SC} PROPOSED SPLICE CAN

THE LOCATION, SIZE, AND TYPE OF MATERIAL OF EXISTING UNDERGROUND AND/OR ABOVEGROUND UTILITIES INDICATED ON THE PLANS ARE NOT REPRESENTED AS BEING ACCURATE, SUFFICIENT OR COMPLETE. NEITHER THE OWNER NOR THE ENGINEER ASSUMES ANY RESPONSIBILITY WHATSOEVER IN RESPECT TO THE ACCURACY, COMPLETENESS, OR SUFFICIENCY OF THE INFORMATION. THERE IS NO GUARANTEE, EITHER EXPRESSED OR IMPLIED, THAT THE LOCATIONS, SIZE AND TYPE OF MATERIAL OF EXISTING UNDERGROUND UTILITIES INDICATED ARE REPRESENTATIVE OF THOSE TO BE ENCOUNTERED IN THE CONSTRUCTION. IT SHALL BE THE CONTRACTOR'S RESPONSIBILITY TO DETERMINE THE ACTUAL LOCATION OF ALL SUCH FACILITIES, INCLUDING SERVICE CONNECTIONS TO UNDERGROUND UTILITIES. PRIOR TO CONSTRUCTION, THE CONTRACTOR SHALL NOTIFY THE UTILITY COMPANIES OF HIS OPERATIONAL PLANS AND SHALL OBTAIN FROM THE RESPECTIVE UTILITY COMPANIES DETAILED INFORMATION AND ASSISTANCE RELATIVE TO THE LOCATION OF THEIR FACILITIES AND THE WORKING SCHEDULE OF THE COMPANIES FOR REMOVAL OR ADJUSTMENT WHERE REQUIRED. IN THE EVENT AN UNEXPECTED UTILITY INTERFERENCE IS ENCOUNTERED DURING CONSTRUCTION, THE CONTRACTOR SHALL IMMEDIATELY NOTIFY THE UTILITY COMPANY OF JURISDICTION. THE OWNER'S REPRESENTATIVE AND/OR THE RESIDENT ENGINEER SHALL ALSO BE IMMEDIATELY NOTIFIED. ANY DAMAGE TO SUCH MAINS AND SERVICES SHALL BE RESTORED TO SERVICE AT ONCE AND PAID FOR BY THE CONTRACTOR AT NO ADDITIONAL COST TO THE CONTRACT.

ALL UTILITY CABLES AND LINES SHALL BE LOCATED BY THE RESPECTIVE UTILITY. CONTACT JULIE (JOINT UTILITY LOCATION INFORMATION FOR EXCAVATORS) FOR UTILITY INFORMATION, PHONE: 1-800-892-0123. ALSO CONTACT AIRPORT DIRECTOR/MANAGER AND AIRPORT PERSONNEL FOR ASSISTANCE IN LOCATING UNDERGROUND AIRPORT CABLES AND/OR UTILITIES. ALSO COORDINATE WORK WITH ALL ABOVEGROUND UTILITIES.

REIL AND AIRFIELD WORK INSTALLATION NOTES

1. ALL WORK, POWER OUTAGES, AND/OR SHUT DOWN OF EXISTING SYSTEMS SHALL BE COORDINATED WITH THE AIRPORT MANAGER. ONCE SHUT DOWN, THE CIRCUITS SHALL BE LABELED AS SUCH TO PREVENT ACCIDENTAL ENERGIZING OF THE RESPECTIVE CIRCUITS. ALL PERSONNEL SHALL FOLLOW U.S. DEPARTMENT OF LABOR OCCUPATIONAL SAFETY & HEALTH ADMINISTRATION (OSHA) 29 CFR PART 1910 OCCUPATIONAL SAFETY & HEALTH STANDARDS FOR ELECTRICAL SAFETY AND LOCKOUT/TAGOUT PROCEDURES INCLUDING, BUT NOT LIMITED TO 29 CFR SECTION 1910.147 THE CONTROL OF HAZARDOUS ENERGY (LOCKOUT/TAGOUT).
2. ALL ELECTRICAL EQUIPMENT (INCLUDING AIRFIELD LIGHTING AND NAVAIDS) AND MATERIALS SHALL BE INSTALLED IN CONFORMANCE WITH NFPA 70 NATIONAL ELECTRIC CODE (NEC) MOST CURRENT ISSUE IN FORCE, THE RESPECTIVE EQUIPMENT MANUFACTURER'S DIRECTIONS, AND ALL OTHER APPLICABLE LOCAL CODES, LAWS, ORDINANCES, AND REQUIREMENTS IN FORCE. ANY INSTALLATIONS WHICH VOID THE UL LISTING, INTERTEK TESTING SERVICES VERIFICATION/ETL LISTING (OR OTHER THIRD PARTY LISTING) AND/OR MANUFACTURER'S WARRANTY OF A DEVICE WILL NOT BE PERMITTED.
3. PER FAA 150/5340-30J, FIGURE A-79, TYPICAL LAYOUT FOR REIL, NOTE 5 STATES THE FOLLOWING: "LOCATE THE REIL EQUIPMENT A MINIMUM DISTANCE OF 40 FT (12.1 M) FROM OTHER RUNWAYS AND TAXIWAYS". NOTE 6 STATES THE FOLLOWING: "IF REILS ARE USED WITH VASI, INSTALL REILS 75 FT (22.8 M) FROM THE RUNWAY EDGE. WHEN INSTALLED WITH OTHER GLIDE SLOPE INDICATORS, INSTALL REILS 40 FT (12.1 M) FROM THE RUNWAY EDGE IF THERE ARE CONCERNS WITH JET BLAST AND WING VORTICES. SEE FAA ORDER JO 6850.2 FOR ADDITIONAL INFORMATION". BASED ON THIS REQUIREMENT REILS SHALL BE LOCATED 40 FEET FROM THE RUNWAY EDGE AND 40 FEET DOWNWIND OF THE RUNWAY THRESHOLD.
4. IN AREAS WHERE THERE IS A CONGESTION OF CABLES OR WHERE THE PROPOSED CABLE CROSSES AN EXISTING CABLE, THE CONTRACTOR IS REQUIRED TO HAND DIG THE TRENCH NECESSARY FOR THE PROPOSED CABLE. AT OTHER LOCATIONS, THE PROPOSED CABLE MAY BE TRENCHED OR PLOWED INTO PLACE. HAND DIGGING, TRENCHING AND/OR PLOWING WILL BE CONSIDERED INCIDENTAL TO THE PROPOSED CABLES AND NO ADDITIONAL COMPENSATION WILL BE ALLOWED
5. THE CONTRACTOR SHALL SECURE, IDENTIFY AND PLACE ALL TEMPORARY EXPOSED WIRING IN CONDUIT, DUCT OR UNIT DUCT TO PREVENT ELECTROCUTION AND FIRE IGNITION SOURCES AS PER THE REQUIREMENTS OF FAA AC 150/5370-2G, SECTION 218.3. ALL LABOR, MATERIALS, AND TIME NECESSARY TO COMPLY WITH THIS REQUIREMENT SHALL BE CONSIDERED INCIDENTAL TO THE CONTRACT AND NO ADDITIONAL COMPENSATION WILL BE ALLOWED.
6. HOMERUN CABLES FOR A RESPECTIVE CIRCUIT THAT ARE INSTALLED IN CONDUIT OR DUCT SHALL BE RUN TOGETHER IN THE SAME RACEWAY OR DUCT.
7. THE CONTRACTOR IS REQUIRED TO FILL IN ALL HOLES AND DEPRESSIONS RESULTING FROM THE NEW WORK, WITH EARTH MATERIAL. THE AREAS SHALL BE COMPACTED TO PREVENT FUTURE SETTLEMENT AND FERTILIZED, SEEDED, AND MULCHED IN ACCORDANCE WITH ITEMS 901 AND 908 RESPECTIVELY. THIS WORK WILL BE CONSIDERED AS AN INCIDENTAL ITEM AND NO ADDITIONAL COMPENSATION WILL BE ALLOWED.
8. HIGH VOLTAGE CIRCUITS (AIRFIELD LIGHTING 5000 VOLT SERIES CIRCUITS OR OTHER CIRCUITS RATED ABOVE 600 VOLTS) AND LOW VOLTAGE CIRCUITS (RATED 600 VOLTS AND BELOW) SHALL NOT BE INSTALLED IN THE SAME WIREWAY, CONDUIT, DUCT, HANDHOLE, OR MANHOLE.
9. NO CONNECTION TO AN ACTIVE LIGHTING, NAVAID, OR OTHER CIRCUIT WILL BE BROKEN UNTIL THE CIRCUIT HAS BEEN TURNED OFF IN ACCORDANCE WITH NOTE 1.

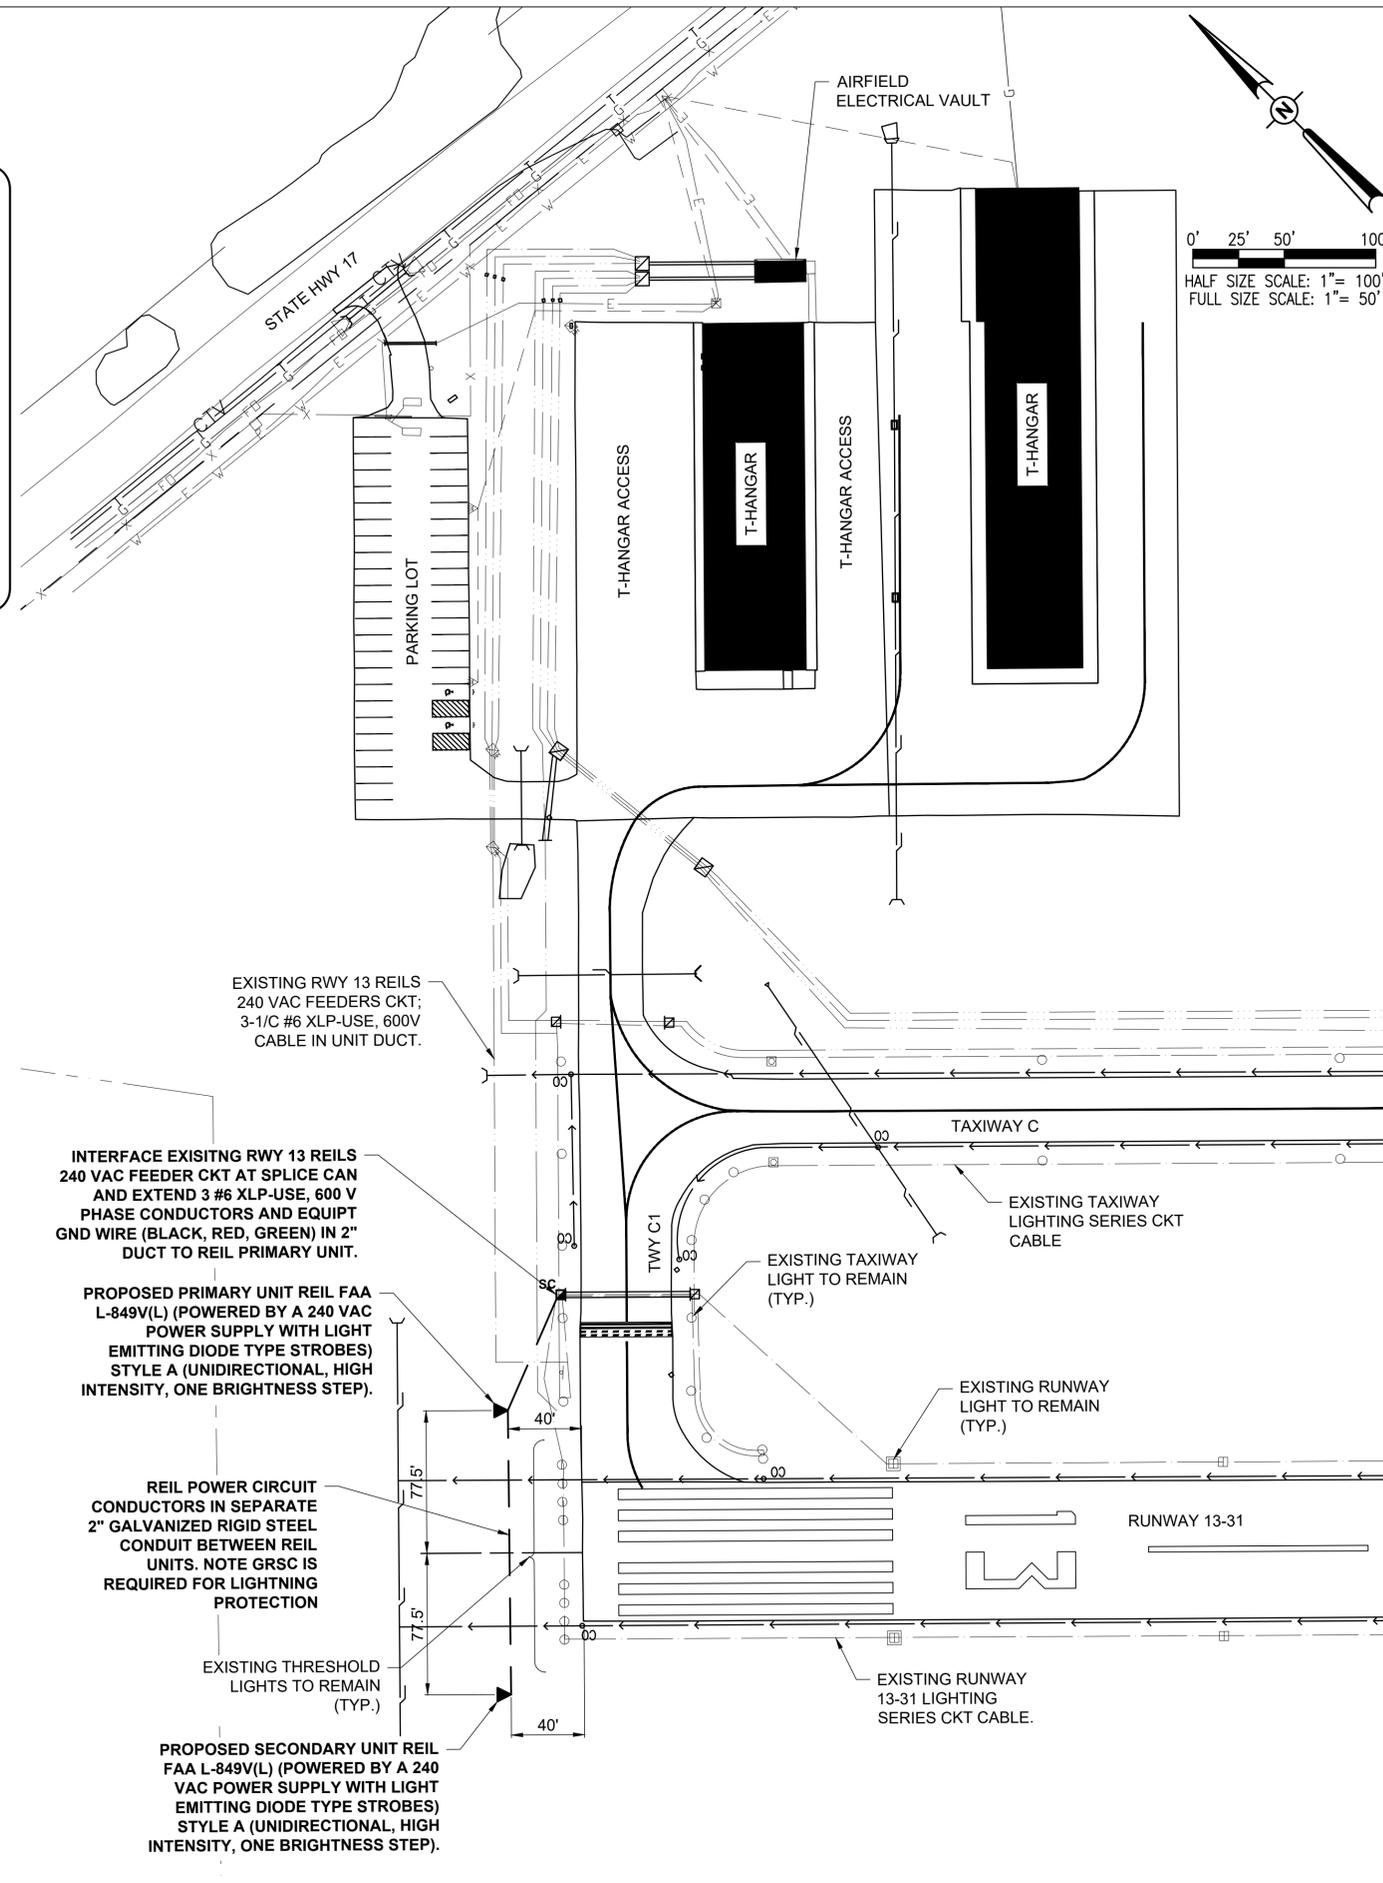

INSTALL RUNWAY END IDENTIFIER LIGHTS ON RUNWAY END 13

SBG: 3-17-SBGP-TBD

IDA No: C75-5140


Contract No. MA035

NO.	DATE	DESCRIPTION		
		DES	DWN	REV

ISSUE: AUGUST, 16 2024
PROJECT NO: 23A1045
CAD FILE: E-102-SITE.DWG
DESIGN BY: KNL 05/19/2024
DRAWN BY: JAP 05/02/2024
REVIEWED BY: KNL 6/10/2024


SHEET TITLE

PROPOSED ELECTRICAL RUNWAY 13 END REILS

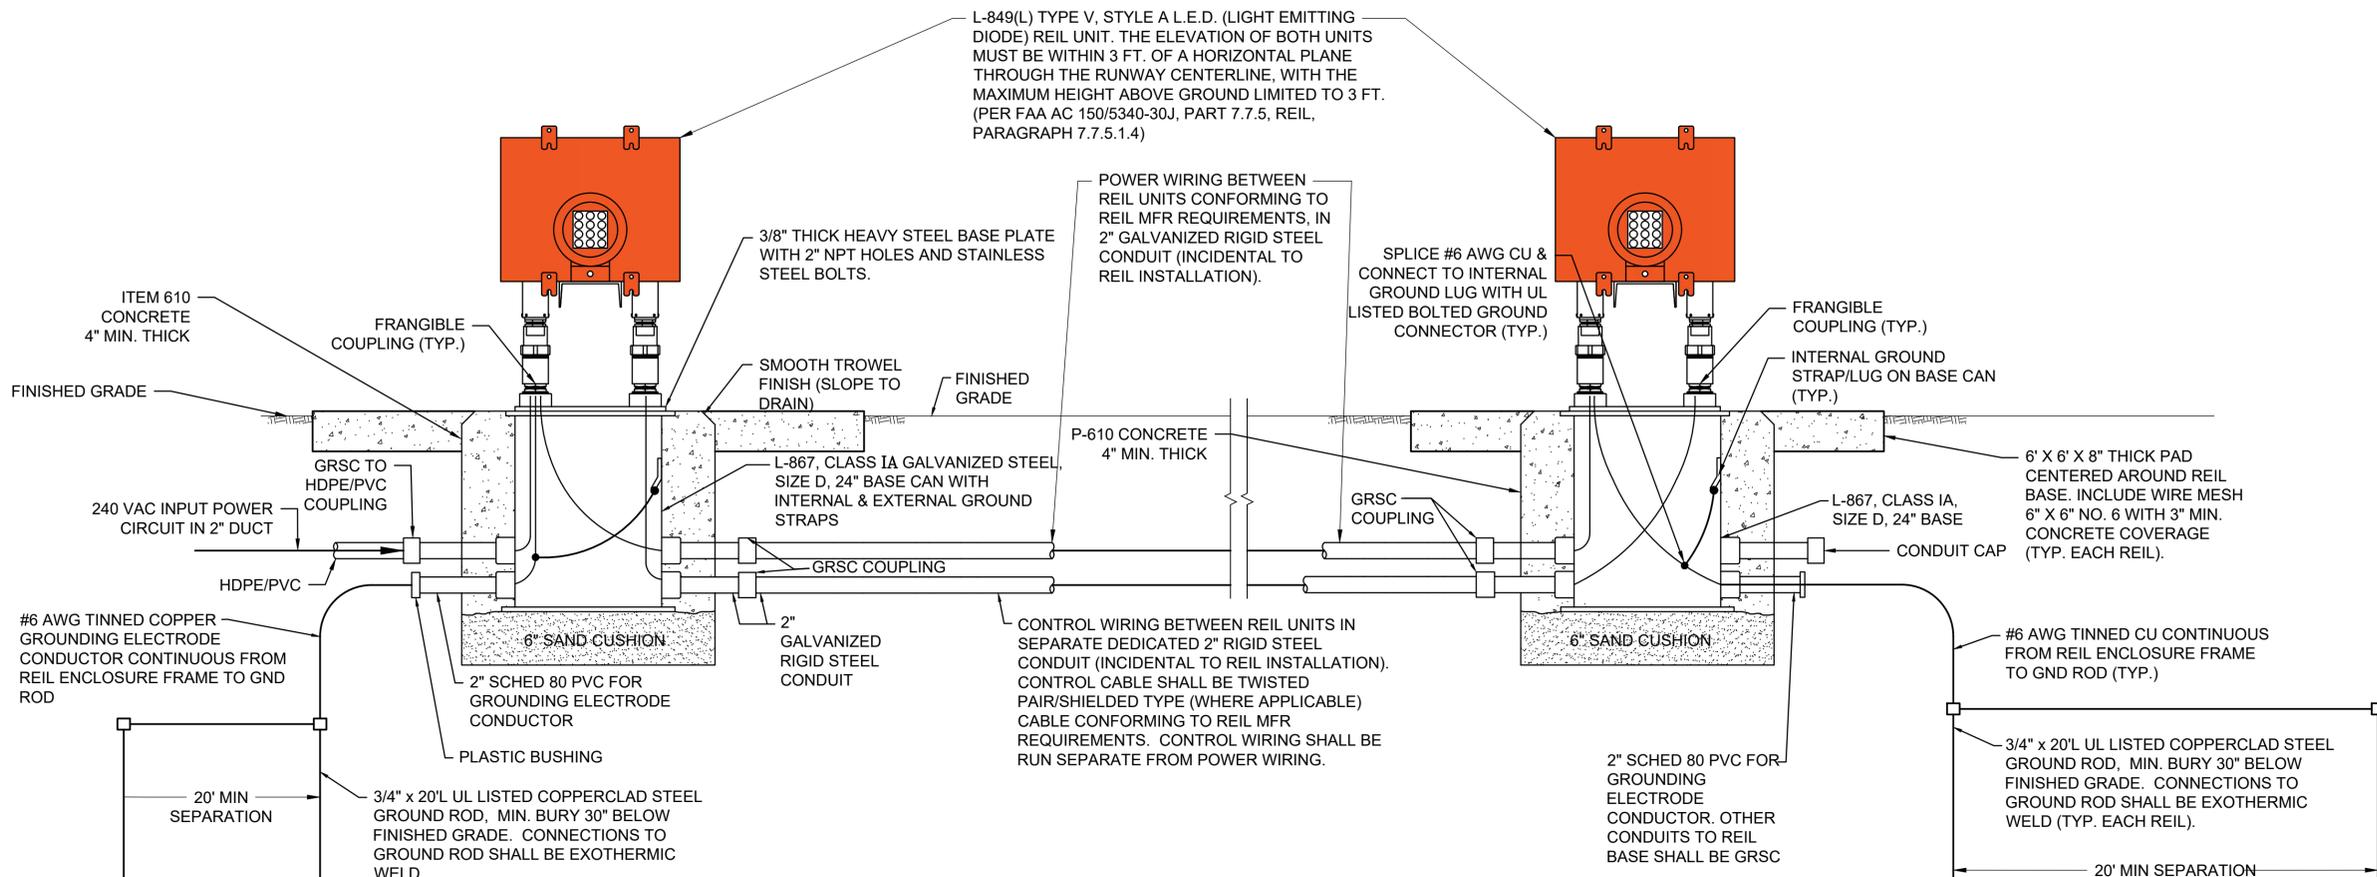

REIL INSTALLATION DETAIL

NOT TO SCALE

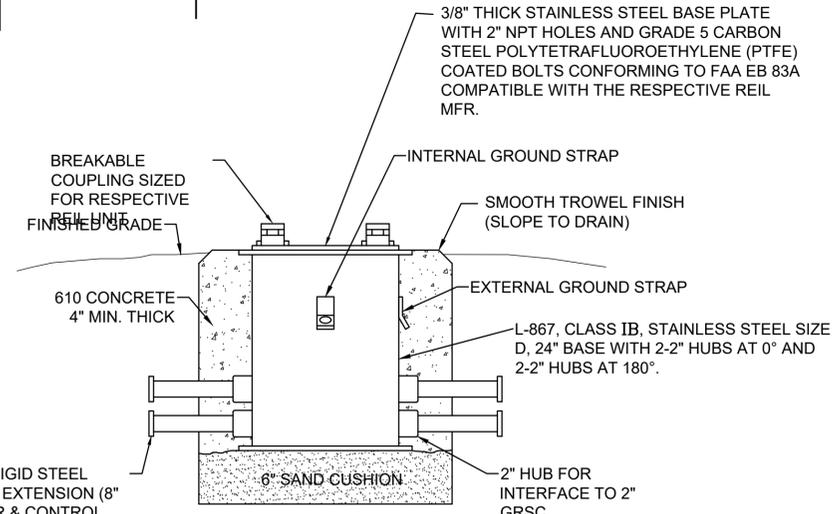

REIL BASE DETAIL

NOT TO SCALE

NOTE:
FOR THE PURPOSE OF ENHANCING SAFETY, EACH BASE MUST HAVE INSTALLED, BY THE MANUFACTURER, AN INTERNAL AND EXTERNAL GROUND STRAP THAT IS AVAILABLE FOR THE PURPOSE OF ATTACHING A GROUND LUG THAT IS CONNECTED TO AN EARTH GROUND OR A SAFETY GROUND CONDUCTOR INSTALLED WITH THE RESPECTIVE CIRCUIT. FOR AIRPORT PROJECTS RECEIVING FEDERAL FUNDS THIS REQUIREMENT IS MANDATORY PER FAA AC 150/5345-42F.

REIL NOTES

1. THE 240 VAC FEEDER FOR THE REIL MASTER/PRIMARY UNIT SHALL INCLUDE AN EQUIPMENT GROUND WIRE THAT SHALL BE LANDED ON THE REIL UNIT HOUSING METAL FRAME. PROVIDE UL LISTED GROUNDING CONNECTORS FOR GROUND WIRE TERMINATIONS. CONNECT ONE WIRE PER LUG OR TERMINAL UNLESS LISTED FOR MULTIPLE CONDUCTORS.
2. POWER WIRING BETWEEN THE REIL MASTER/PRIMARY UNIT AND THE REIL SECONDARY UNIT SHALL CONFORM TO THE RESPECTIVE REIL MANUFACTURER'S REQUIREMENTS AND RECOMMENDATIONS, SUITABLE FOR WET LOCATION, 600 VOLT MINIMUM INSULATION RATING. INCLUDE AN EQUIPMENT GROUND WIRE WITH THE POWER CIRCUIT BETWEEN THE REIL MASTER/PRIMARY UNIT AND THE REIL SECONDARY UNIT. CONNECT EQUIPMENT GROUND WIRE TO EACH REIL UNIT HOUSING METAL FRAME.
3. REILS SHALL BE FAA APPROVED CONFORMING TO FAA AC 150/5345-51B "SPECIFICATION FOR DISCHARGE-TYPE FLASHING LIGHT EQUIPMENT", L-849(L) (LIGHT EMITTING DIODE) TYPE V REIL POWERED BY CONSTANT CURRENT 6.6 AMP POWER SUPPLY, STYLE A - UNIDIRECTIONAL, HIGH INTENSITY, ONE BRIGHTNESS STEP. SEE SPECIFICATION ITEM L-125 FOR ADDITIONAL REQUIREMENTS ON REILS.
4. REILS SHALL BE LOCATED AS DETAILED ON THE SITE PLANS. SPACE THE REIL LIGHT UNITS EQUALLY FROM THE RUNWAY CENTERLINE. REILS SHALL BE AIMED AT ANGLE 10 DEGREES VERTICALLY AND TOED OUT 15 DEGREES FROM THE LINE PARALLEL TO THE RUNWAY CENTERLINE.
5. ANY AND ALL TRENCHES AND DISTURBED AREAS WILL BE BACKFILLED AND RESTORED TO A SMOOTH GRADE AND SEEDED TO THE SATISFACTION OF THE ENGINEER. ALL TRENCH SETTLEMENT SHALL BE CORRECTED FOR A PERIOD OF ONE YEAR. RESTORATION, GRADING, SEEDING, AND MULCHING OF AREAS DISTURBED DURING THE REIL INSTALLATION AND ASSOCIATED CABLE WILL BE INCIDENTAL TO THE INSTALLATION OF THE REILS.
6. **GROUNDING FOR REILS.** GROUNDING FOR REILS SHALL CONFORM TO THE RESPECTIVE REIL MANUFACTURER'S INSTALLATION INSTRUCTIONS, AS DETAILED ON THE PLANS, AND AS SPECIFIED HEREIN. FURNISH AND INSTALL TWO 3/4-INCH DIAMETER BY 20-FOOT LONG COPPERCLAD STEEL GROUND RODS AT EACH REIL UNIT. GROUND RODS SHALL BE BURIED 30" MINIMUM BELOW GRADE. BOND EACH REIL UNIT HOUSING AND THE REIL BASE CAN TO THE RESPECTIVE GROUND ROD IN ACCORDANCE WITH THE MANUFACTURER'S INSTRUCTIONS WITH A #6 AWG TINNED SOLID OR STRANDED (PER REIL MANUFACTURER REQUIREMENTS) COPPER GROUNDING ELECTRODE CONDUCTOR. ALL CONNECTIONS TO GROUND RODS SHALL BE EXOTHERMIC WELD AS MANUFACTURED BY CADWELD, THERMOWELD, ULTRAWELD, OR APPROVED EQUAL. CONNECTIONS TO REIL UNIT FRAMES SHALL BE AS RECOMMENDED BY THE MANUFACTURER OR WITH UL LISTED GROUNDING CONNECTORS. CONNECTIONS TO THE BASE / TRANSFORMER CAN SHALL BE WITH UL LISTED BOLTED CONNECTOR OR ONE-HOLE COMPRESSION LUG & 3/8" STAINLESS STEEL BOLTS, NUTS, & WASHERS. TEST GROUND RODS AND RECORD EARTH RESISTANCE AT EACH REIL.
7. PRIOR TO FINAL ACCEPTANCE AND ACTIVATION, THE COMPLETED REIL INSTALLATION WILL REQUIRE A FLIGHT CHECK TO BE SCHEDULED AND CONDUCTED BY THE FAA. IT SHALL BE THE CONTRACTOR'S RESPONSIBILITY TO HAVE A REPRESENTATIVE PRESENT TO MAKE ANY NECESSARY ADJUSTMENTS IN THE INSTALLATION AND/OR AIMING OF THE REIL UNITS FOR THE FLIGHT SYSTEM CHECKS.

INSTALL RUNWAY END IDENTIFIER LIGHTS ON RUNWAY END 13

SBG: 3-17-SBGP-TBD

IDA No: C75-5140


Contract No. MA035

NO.	DATE	DESCRIPTION		
		DES	DWN	REV

ISSUE: AUGUST, 16 2024
PROJECT NO: 23A1045
CAD FILE: E-501-DETL.DWG
DESIGN BY: KNL 05/19/2024
DRAWN BY: JAP 05/02/2024
REVIEWED BY: KNL 6/10/2024


SHEET TITLE

REIL DETAILS AND NOTES

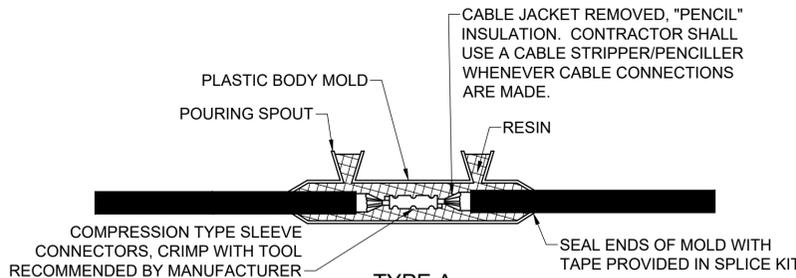


TYPE A

FOR SPLICES IN LOW VOLTAGE CABLE (600V) HOMERUNS FOR EXTENSIONS TO EXISTING LOW VOLTAGE CABLES ONLY. TYPE A SPLICES SHALL BE MADE IN SPLICE CANS, HANDHOLES, MANHOLES, OR JUNCTIONS BOXES

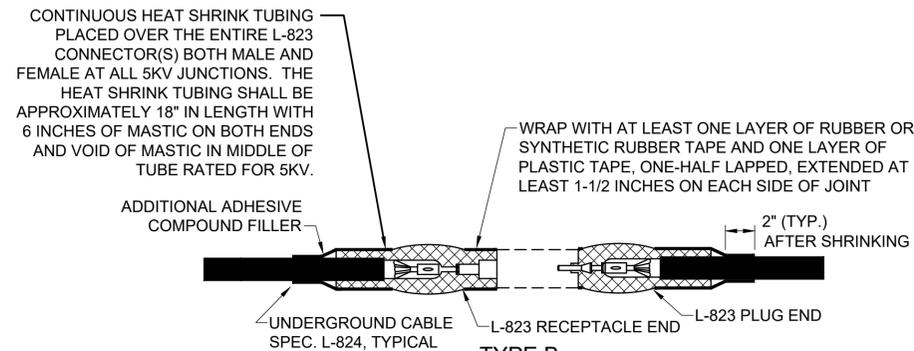

TYPE B

FOR SPLICES AT JUNCTION OF HOMERUN WITH LOOP CIRCUIT AND FOR SPLICES IN HOMERUNS TO EXISTING CABLES

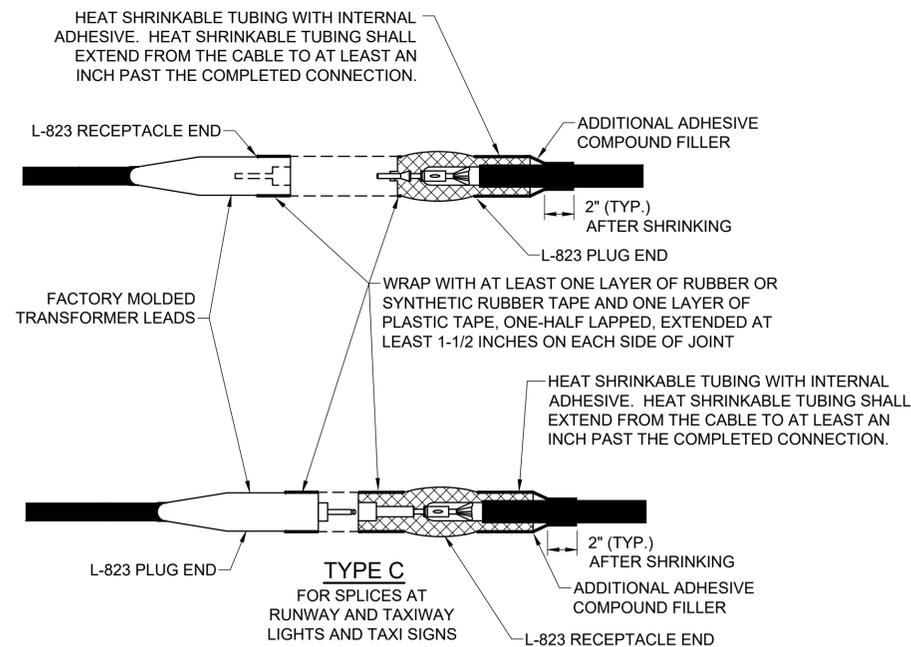

TYPE C


FOR SPLICES AT RUNWAY AND TAXIWAY LIGHTS AND TAXI SIGNS

NOTES:
INSIDE DIAMETER OF CONNECTOR SHALL PROPERLY MATCH THE OUTSIDE DIAMETER OF CABLE.

CABLE SPLICES

NOTES:

- SPLICE DETAILS ARE PROVIDED FOR NEW WORK AND TO ASSIST IN REPAIRS OF ACCIDENTAL OR UNEXPECTED INTERRUPTIONS AND/OR CUTS TO AIRFIELD LIGHTING CABLES.
- KEEP ON HAND A MINIMUM OF 10 SETS OF SPLICE KITS FOR L-823 CONNECTORS AND A MINIMUM OF 10 SETS OF TYPE A LOW VOLTAGE SPLICE KITS TO ACCOMMODATE REPAIRS.
- EVERY AIRFIELD LIGHTING CABLE SPICER SHALL BE QUALIFIED IN MAKING CABLE SPLICES AND TERMINATIONS ON CABLES RATED AT AND/OR ABOVE 5,000 VOLTS AC TO COMPLY WITH THE REQUIREMENTS OF FAA AC 150/5370-10G ITEM L-108.
- INSIDE DIAMETER OF RESPECTIVE CABLE CONNECTOR SHALL PROPERLY MATCH OUTSIDE DIAMETER OF CABLE.
- WHEN PREPARING CABLE FOR SPLICES, THE CONTRACTOR SHALL USE A CABLE STRIPPER/PENCILLER WHENEVER CABLE CONNECTIONS ARE MADE.
- WRAP ALL PRIMARY AND SECONDARY POWER CONNECTIONS WITH SUFFICIENT LAYERS OF HIGH VOLTAGE ELECTRICAL INSULATING TAPE (RUBBER SPLICING TAPE SUITABLE FOR PRIMARY ELECTRICAL INSULATION FOR SPLICING CABLE FROM 600 VOLTS TO 69,000 VOLTS) AND COVER WITH VINYL ELECTRICAL TAPE (ALL-WEATHER VINYL INSULATING TAPE SUITABLE FOR PROTECTIVE JACKETING FOR HIGH-VOLTAGE CABLE SPLICES AND REPAIRS) FOR FULL VALUE OF CABLE INSULATION VOLTAGE. PER ILLINOIS STANDARD SPECIFICATIONS FOR CONSTRUCTION OF AIRPORTS ITEM 108, ITEM 125, AND FAA AC 150/5370-10H ITEM L-108 AND L-125. HIGH VOLTAGE ELECTRICAL INSULATING TAPE SHALL BE 3M SCOTCH 130C LINERLESS RUBBER SPLICING TAPE (2 INCHES WIDE) OR APPROVED EQUIVALENT, AND VINYL ELECTRICAL TAPE SHALL BE 3M SCOTCH 88 (1.5 INCHES WIDE) OR APPROVED EQUIVALENT. TAPES MUST BE RATED SUITABLE FOR THE APPLICATION.
- PROVIDE CABLE TAGS TO IDENTIFY THE RESPECTIVE CIRCUITS ALL POINTS OF ACCESS INCLUDING L-867 BASES, L-868 BASES, HANDHOLES, MANHOLES, JUNCTION BOXES, AND WIREWAYS.
- CONNECTION OF CONDUCTORS MUST BE MADE BY USING CRIMP CONNECTORS AND A CRIMPING TOOL APPROVED BY THE CONNECTOR/LUG MANUFACTURER. THE TOOL MUST PRODUCE A COMPLETE CRIMP BEFORE IT CAN BE REMOVED. FOR THE L-823 CONNECTORS, THE CRIMPING TOOL USED MUST BE LISTED BY THE L-823 KIT MANUFACTURER. MAKE THE NUMBER AND TYPE OF CRIMPS PER THE KIT MANUFACTURER'S INSTRUCTIONS.

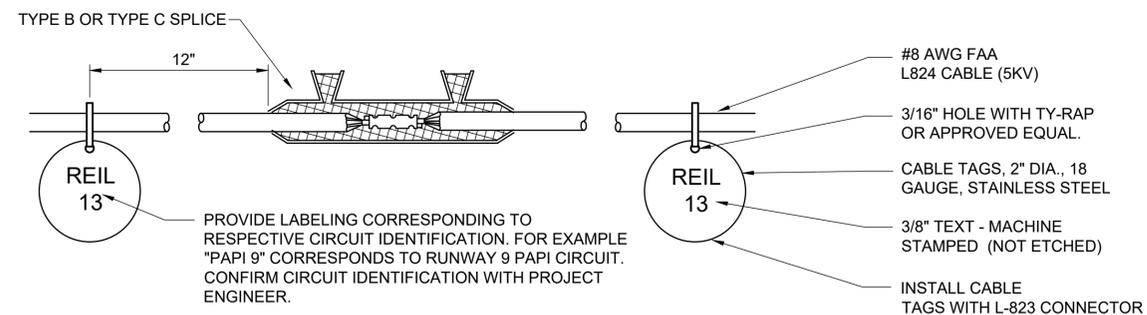

CABLE TAG DETAIL
"NOT TO SCALE"

- CONTRACTOR SHALL PROVIDE CABLE CIRCUIT IDENTIFICATION MARKERS ATTACHED TO BOTH SIDES OF EACH CABLE CONNECTION. PROVIDE TWO CABLE TAGS FOR CABLES IN MANHOLES; ONE AT ENTRY TO MANHOLE AND SECOND ONE AT EXIT FROM MANHOLE.
- CABLE IDENTIFICATION TAGS SHALL BE STAINLESS STEEL OR BRASS.
- THE CABLE SHALL THOROUGHLY BE CLEANED PRIOR TO THE INSTALLATION OF THE L-823 CONNECTOR KIT.
- ATTACH EACH CABLE TIE ENOUGH TO HOLD IN PLACE WITHOUT COMPRESSING EDGE OF CABLE TAG INTO CONDUCTOR. TRIM OFF EXCESS CABLE TIE.
- CABLE TAGS SHALL BE PROVIDED AT ALL POINTS OF ACCESS INCLUDING L-867 BASES, L-868 BASES, HANDHOLES, MANHOLES, JUNCTION BOXES, AND WIREWAYS.
- CABLE TAGS SHALL BE LABELED AS FOLLOWS FOR RESPECTIVE AIRFIELD LIGHTING/NAVAID CIRCUITS.
RUNWAY 13 REIL CIRCUIT: REIL 13

INSTALL RUNWAY END IDENTIFIER LIGHTS ON RUNWAY END 13

SBG: 3-17-SBG-P-TBD

IDA No: C75-5140


Contract No. MA035

NO.	DATE	DESCRIPTION		
		DES	DWN	REV


ISSUE: AUGUST, 16 2024
PROJECT NO: 23A1045
CAD FILE: E-503-DETL.DWG
DESIGN BY: KNL 05/19/2024
DRAWN BY: JAP 05/02/2024
REVIEWED BY: LDH 06/15/2024

SHEET TITLE


AIRFIELD LIGHTING CABLE SPLICE DETAILS

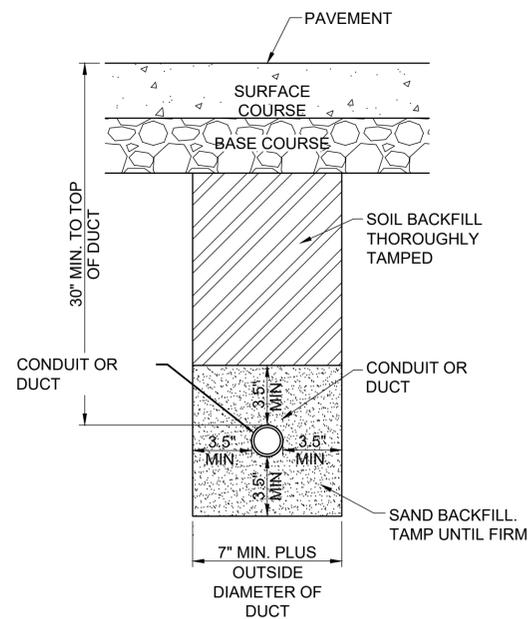

CONDUIT IN TRENCH - PAVED AREAS
"NOT TO SCALE"

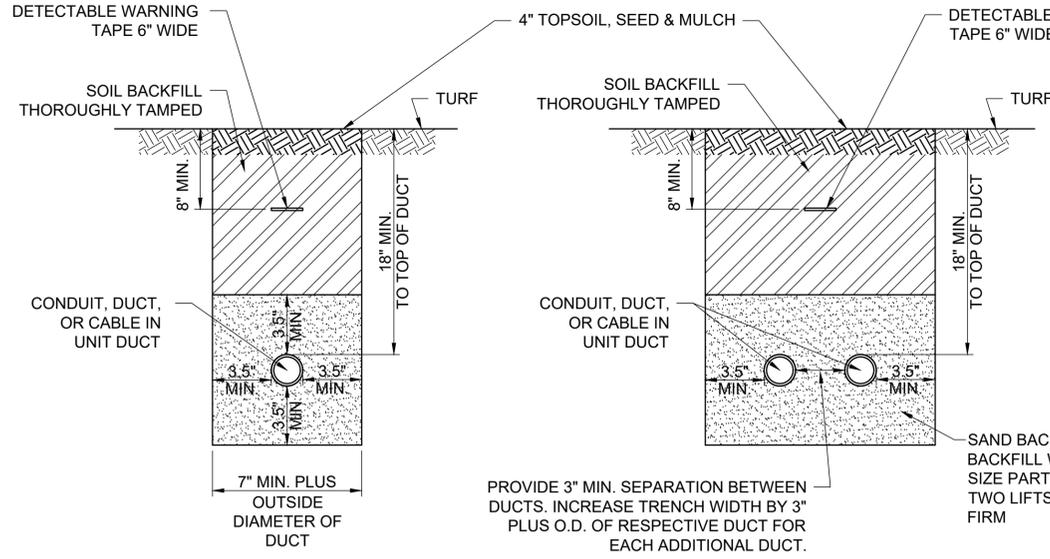

CONDUIT IN TRENCH - NON-PAVEMENT AREAS
"NOT TO SCALE"

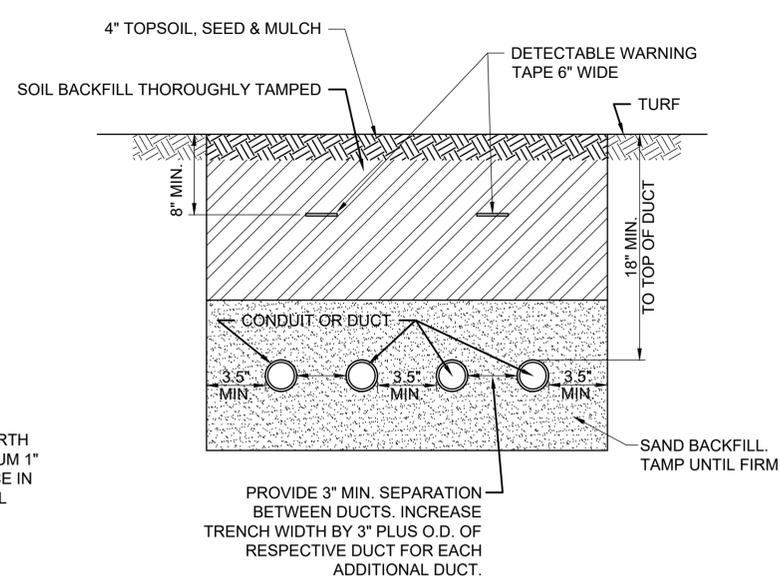

NOTES:

- DIMENSIONS FOR COVERAGE AND SEPARATION BETWEEN DUCTS ARE MINIMUM.
- TRENCHES WITH MORE THAN TWO DUCTS OR CABLE IN UNIT DUCTS SHALL BE INCREASED 3" IN WIDTH PLUS DIAMETER OF RESPECTIVE DUCT FOR EACH ADDITIONAL CONDUIT, DUCT, OR CABLE IN UNIT DUCT; IF SPECIFIED ON PLANS TWO PARALLEL TRENCHES MAY BE CONSTRUCTED.
- DEPTH OF TRENCHES SHALL BE AS SHOWN ABOVE UNLESS OTHERWISE SPECIFIED ON THE PLANS. MINIMUM COVER REQUIREMENTS FOR CABLES AND DUCTS AT AIRPORT RUNWAYS AND ADJACENT AREAS WHERE TRESPASSING IS PROHIBITED IS 18 INCHES PER NEC 300.5 AND 300.50. MINIMUM COVER REQUIREMENTS FOR DUCTS CONTAINING NAVAID FEEDER CIRCUITS SHALL BE 24". MINIMUM COVER REQUIREMENTS FOR DUCTS LOCATED BELOW PAVEMENT OR ROADWAYS IS 30". MINIMUM COVER REQUIREMENTS FOR DUCTS LOCATED IN AREAS SUBJECT TO FARMING IS 42". MINIMUM COVER FOR DUCTS CONTAINING SECONDARY ELECTRIC SERVICE CONDUCTORS SHALL BE 36" OR AS REQUIRED BY THE SERVING ELECTRIC UTILITY COMPANY. ADJUST/INCREASE BURIAL DEPTHS TO ACCOMMODATE SITE CONDITIONS, DRAINAGE AND/OR OBSTRUCTIONS. COVER IS DEFINED AS THE SHORTEST DISTANCE IN INCHES MEASURED BETWEEN A POINT ON THE TOP SURFACE OF ANY DIRECT-BURIED CONDUCTOR, CABLE, CONDUIT, OR OTHER RACEWAY AND THE TOP SURFACE OF FINISHED GRADE, CONCRETE OR SIMILAR COVER.
- HIGH-VOLTAGE CIRCUIT WIRING (AIRFIELD LIGHTING 5000 VOLT SERIES CIRCUITS AND/OR OTHER CIRCUITS RATED ABOVE 600 VOLTS) AND LOW-VOLTAGE CIRCUIT WIRING (RATED 600 VOLTS AND BELOW) SHALL MAINTAIN SEPARATION FROM EACH OTHER. HIGH-VOLTAGE WIRING AND LOW-VOLTAGE WIRING SHALL NOT BE INSTALLED IN THE SAME WIREWAY, CONDUIT, DUCT, RACEWAY, HANDHOLE, OR JUNCTION BOX. CORRECTIVE WORK WILL BE REQUIRED TO SEPARATE HIGH VOLTAGE SERIES CIRCUIT CONDUCTORS FROM LOW VOLTAGE CONDUCTORS WHERE THEY ARE INSTALLED IN THE SAME RACEWAY.
- SERVICE CONDUCTORS SHALL NOT BE INSTALLED IN THE SAME RACEWAY, CONDUIT, DUCT, OR HANDHOLE WITH FEEDER CIRCUITS, BRANCH CIRCUITS OR CONTROL CIRCUITS.
- COMMUNICATION CIRCUITS SHALL NOT BE INSTALLED IN THE SAME RACEWAY, CONDUIT, DUCT, OR HANDHOLE WITH POWER CIRCUITS.
- HOME RUN CABLES FOR A RESPECTIVE CIRCUIT SHALL BE INSTALLED IN THE SAME RACEWAY OR DUCT.
- COORDINATE DUCT INTERFACE TO MANHOLES AND HANDHOLES. FIELD CUT OPENINGS FOR CONDUITS AND DUCTS TO INTERFACE TO MANHOLES AND/OR HANDHOLES. CUT WALL OF RESPECTIVE HANDHOLE OR MANHOLE WITH A TOOL DESIGNED FOR MATERIAL TO BE CUT. SIZE HOLES FOR RESPECTIVE DUCTS, CONDUITS, AND TERMINATION FITTINGS AND SEAL AROUND PENETRATIONS. ALL CORING, INTERFACE, CUTTING, AND SEALING WILL BE CONSIDERED INCIDENTAL TO THE RESPECTIVE DUCT INSTALLATION AND/OR RESPECTIVE HANDHOLE/MANHOLE INSTALLATION. PROVIDE BUSHINGS OR BELLS AT CONDUIT TERMINATIONS IN ELECTRICAL HANDHOLES OR MANHOLES.
- ALL DISTURBED SURFACES SHALL BE RESTORED TO THEIR ORIGINAL CONDITION. COST IS INCIDENTAL TO TRENCH.
- ALL ELECTRICAL EQUIPMENT AND MATERIALS SHALL BE INSTALLED IN CONFORMANCE WITH NFPA 70 - NATIONAL ELECTRICAL CODE (NEC) MOST CURRENT ISSUE IN FORCE, THE RESPECTIVE EQUIPMENT MANUFACTURER'S DIRECTIONS AND ALL OTHER APPLICABLE LOCAL CODES, LAWS, ORDINANCES, AND REQUIREMENTS IN FORCE. ANY INSTALLATIONS WHICH VOID THE U.L. LISTING, INTERTEK TESTING SERVICES VERIFICATION/ETL LISTING (OR OTHER THIRD PARTY LISTING) AND/OR THE MANUFACTURER'S WARRANTY OF A DEVICE WILL NOT BE PERMITTED.
- CONTRACTOR SHALL COORDINATE WORK AND ANY POWER OUTAGES AND/OR SHUT DOWN OF SYSTEMS WITH THE RESPECTIVE FACILITY OWNER PERSONNEL AND THE AIRPORT MANAGER/DIRECTOR. ONCE SHUT DOWN, THE CIRCUITS SHALL BE LABELED AS SUCH TO PREVENT ACCIDENTAL ENERGIZING OF THE RESPECTIVE CIRCUITS. ALL PERSONNEL SHALL FOLLOW U.S. DEPARTMENT OF LABOR OCCUPATIONAL SAFETY & HEALTH ADMINISTRATION (OSHA) 29 CFR PART 1910 OCCUPATIONAL SAFETY & HEALTH STANDARDS FOR ELECTRICAL SAFETY AND LOCKOUT/TAGOUT PROCEDURES INCLUDING, BUT NOT LIMITED TO, 29 CFR SECTION 1910.147 THE CONTROL OF HAZARDOUS ENERGY (LOCKOUT/TAGOUT).
- THE LOCATION, SIZE AND TYPE OF MATERIAL OF EXISTING UNDERGROUND AND/OR ABOVEGROUND UTILITIES INDICATED ON THE PLANS IS NOT REPRESENTED AS BEING ACCURATE, SUFFICIENT OR COMPLETE. NEITHER THE OWNER NOR THE ENGINEER ASSUMES ANY RESPONSIBILITY WHATSOEVER IN RESPECT TO ACCURACY, COMPLETENESS, OR SUFFICIENCY OF THE INFORMATION. THERE IS NO GUARANTEE EITHER EXPRESSED OR IMPLIED, THAT THE LOCATIONS, SIZE AND TYPE OF MATERIAL OF EXISTING UNDERGROUND UTILITIES INDICATED ARE REPRESENTATIVE OF THOSE TO BE ENCOUNTERED IN THE CONSTRUCTION. IT SHALL BE THE CONTRACTOR'S RESPONSIBILITY TO DETERMINE THE ACTUAL LOCATION OF ALL SUCH FACILITIES, INCLUDING SERVICE CONNECTIONS TO UNDERGROUND UTILITIES. PRIOR TO CONSTRUCTION, THE CONTRACTOR SHALL NOTIFY THE UTILITY COMPANIES OF HIS OPERATIONAL PLANS AND SHALL OBTAIN FROM THE RESPECTIVE UTILITY COMPANIES DETAILED INFORMATION AND ASSISTANCE RELATIVE TO THE LOCATION OF THEIR FACILITIES AND THE WORKING SCHEDULE OF THE COMPANIES FOR REMOVAL OR ADJUSTMENT WHERE REQUIRED. IN THE EVENT AN UNEXPECTED UTILITY INTERFERENCE IS ENCOUNTERED DURING CONSTRUCTION, THE CONTRACTOR SHALL IMMEDIATELY NOTIFY THE UTILITY COMPANY OF JURISDICTION. THE OWNER'S REPRESENTATIVE AND/OR THE RESIDENT ENGINEER SHALL ALSO BE IMMEDIATELY NOTIFIED. ANY DAMAGE TO SUCH MAINS AND SERVICES SHALL BE RESTORED TO SERVICE AT ONCE AND PAID FOR BY THE CONTRACTOR AT NO ADDITIONAL COST TO THE CONTRACT. ALL UTILITY CABLES AND LINES SHALL BE LOCATED BY THE RESPECTIVE UTILITY. CONTACT JULIE (JOINT UTILITY LOCATION INFORMATION FOR EXCAVATORS) FOR UTILITY INFORMATION PHONE; 1-800-892-0123. CONTACT THE FAA (FEDERAL AVIATION ADMINISTRATION) FOR ASSISTANCE IN LOCATING FAA CABLES AND UTILITIES. ALSO CONTACT AIRPORT DIRECTOR/MANAGER AND AIRPORT PERSONNEL FOR ASSISTANCE IN LOCATING UNDERGROUND AIRPORT CABLES AND/OR UTILITIES. ALSO COORDINATE WORK WITH ALL ABOVEGROUND UTILITIES.
- ADJUSTMENTS TO DUCT BANK ROUTES MIGHT BE REQUIRED TO ACCOMMODATE EXISTING SITE CONDITIONS AND UNDERGROUND LINES AND UTILITIES. CONTRACTOR SHALL FIELD VERIFY EXISTING SITE CONDITIONS. CONTRACTOR SHALL COORDINATE DUCT ROUTE ADJUSTMENTS WITH THE RESIDENT PROJECT REPRESENTATIVE AND THE AIRPORT MANAGER.
- CONTRACTOR SHALL LOCATE AND MARK ALL EXISTING CABLES, LINES, OR UTILITIES WITHIN 10 FT OF PROPOSED EXCAVATING/TRENCHING AREA. ANY CABLES, LINES, AND UTILITIES FOUND INTERFERING WITH PROPOSED EXCAVATION OR CABLE/TRENCHING SHALL BE HAND DUG AND EXPOSED. ANY DAMAGED CABLES OR OTHER UTILITIES SHALL BE IMMEDIATELY REPAIRED TO THE SATISFACTION OF THE RESPECTIVE OWNER'S REPRESENTATIVE AT THE CONTRACTOR'S EXPENSE. THE RESIDENT ENGINEER/RESIDENT TECHNICIAN AND OWNER SHALL BE NOTIFIED IMMEDIATELY IF ANY CABLES OR OTHER UTILITIES ARE DAMAGED.
- PAYMENT FOR LOCATING AND MARKING UNDERGROUND UTILITIES AND CABLES WILL NOT BE PAID FOR SEPARATELY, BUT SHALL BE CONSIDERED INCIDENTAL TO THE RESPECTIVE DUCT INSTALLATION.
- THE CONTRACTOR WILL DETERMINE IF THERE IS A CONFLICT BETWEEN THE INSTALLATION OF THE PROPOSED ELECTRICAL DUCTS AND ANY EXISTING UTILITIES. THE CONTRACTOR WILL MAKE ALL NECESSARY ADJUSTMENTS IN DEPTH OF INSTALLATION TO AVOID ANY AND ALL PROPOSED UNDERGROUND IMPROVEMENTS
- CONDUITS FOR DIRECT BURIAL OR CONCRETE ENCASED DUCT BANK SHALL BE SCHEDULE 40 (MINIMUM) PVC CONDUIT, UL-LISTED, RATED FOR 90°C CABLE-CONFORMING TO NEMA STANDARD TC-2 AND UL 651, LISTED SUITABLE FOR UNDERGROUND USE EITHER DIRECT-BURIED OR ENCASED IN CONCRETE, OR SCHEDULE 40 (MINIMUM) HDPE CONDUIT, UL LISTED, CONFORMING TO NEMA STANDARD TC-7 AND UL 651B AND LISTED SUITABLE FOR UNDERGROUND USE; EITHER DIRECT BURY OR ENCASED IN CONCRETE. HEAVIER WALL CONDUITS SHALL BE FURNISHED FOR RESPECTIVE APPLICATIONS WHERE DETAILED HEREIN.
- CONDUITS FOR DIRECTIONAL BORING SHALL BE SCHEDULE 40 PVC CONDUIT OR SCHEDULE 80 PVC CONDUIT, UL-LISTED, RATED FOR 90°C CABLE-CONFORMING TO NEMA STANDARD TC-2 AND UL 651 AND SUITABLE FOR DIRECTIONAL BORING INSTALLATION, SCHEDULE 80 HDPE CONDUIT, UL-LISTED, CONFORMING TO NEMA STANDARD TC-7 AND UL 651B AND SUITABLE FOR DIRECTIONAL BORING INSTALLATION, OR WALL TYPE MINIMUM SDR 11 HDPE CONDUIT MANUFACTURED IN ACCORDANCE WITH ASTM D-3350 (SPECIFICATION OF POLYETHYLENE PLASTICS PIPE AND FITTINGS MATERIALS) AND ASTM F2160 (STANDARD SPECIFICATION FOR SOLID WALL, HIGH-DENSITY POLYETHYLENE CONDUIT BASED ON CONTROLLED OUTSIDE DIAMETER), AND SUITABLE FOR DIRECTIONAL BORING INSTALLATION. PER NEC 300.5 (K), RACEWAYS INSTALLED USING DIRECTIONAL BORING EQUIPMENT SHALL BE APPROVED FOR THE PURPOSE.
- UNDERGROUND DUCTS INSTALLED BY DIRECTIONAL-BORING METHOD SHALL BE INSTALLED IN A MANNER THAT WILL NOT DAMAGE ANY EXISTING UNDERGROUND UTILITIES, AND SHALL NOT DISTURB OR DAMAGE THE RESPECTIVE PAVEMENT OR ROADWAY SURFACE. DUCTS SHALL BE DIRECTIONAL-BORED AT THE LOCATIONS SHOWN ON THE CONSTRUCTION PLANS. THE DUCTS WILL BE BORED AT A MINIMUM DEPTH OF 42 IN. BELOW THE RESPECTIVE PAVEMENT IT IS BEING BORED UNDER.
- A PULL WIRE SHALL BE INSTALLED IN EACH CONDUIT OR DUCT TO BE LEFT VACANT.
- CONTRACTOR SHALL COORDINATE DUCT MARKING WITH AIRPORT.
- ALL POWER AND CONTROL CABLES IN HANDHOLES, MANHOLES, AND JUNCTION BOXES SHALL BE TAGGED TO IDENTIFY THE RESPECTIVE CABLE. A MINIMUM OF TWO TAGS SHALL BE PROVIDED ON EACH CABLE IN A MANHOLE; ONE AT THE CABLE ENTRANCE AND ONE AT THE CABLE EXIT. CABLE TAGS SHALL BE STAMPED BRASS TAGS OR OTHER WEATHERPROOF/WATERPROOF CORROSION RESISTANT MATERIAL.

INSTALL RUNWAY END IDENTIFIER LIGHTS ON RUNWAY END 13

SBG: 3-17-SBGP-TBD

IDA No: C75-5140


Contract No. MA035

NO.	DATE	DESCRIPTION		
		DES	DWN	REV


ISSUE: AUGUST, 16 2024
PROJECT NO: 23A1045
CAD FILE: E-504-DETL.DWG
DESIGN BY: KNL 05/19/2024
DRAWN BY: JAP 05/02/2024
REVIEWED BY: KNL 6/10/2024

SHEET TITLE


CONDUIT TRENCH DETAIL

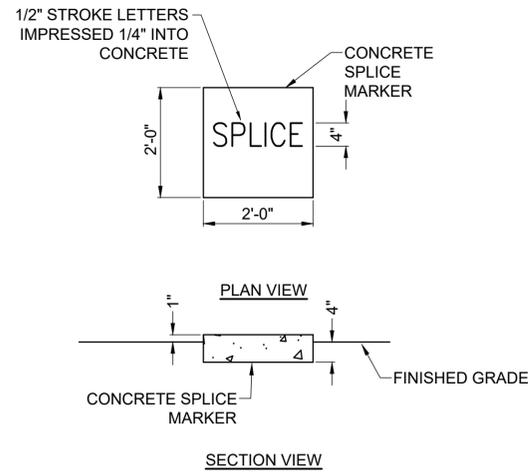


TURF CABLE MARKERS
"NOT TO SCALE"

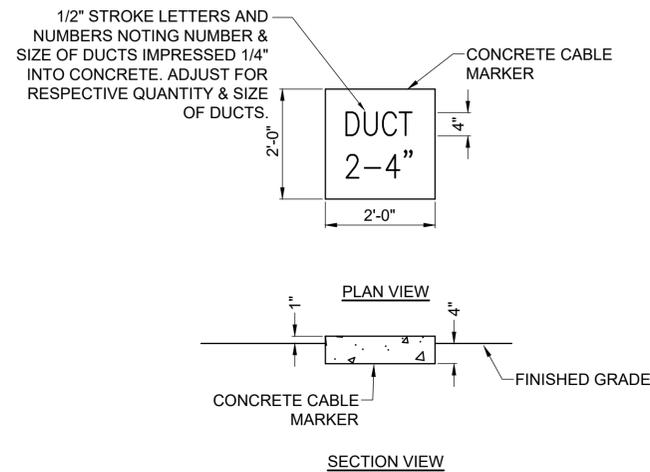

TURF CABLE MARKERS
"NOT TO SCALE"

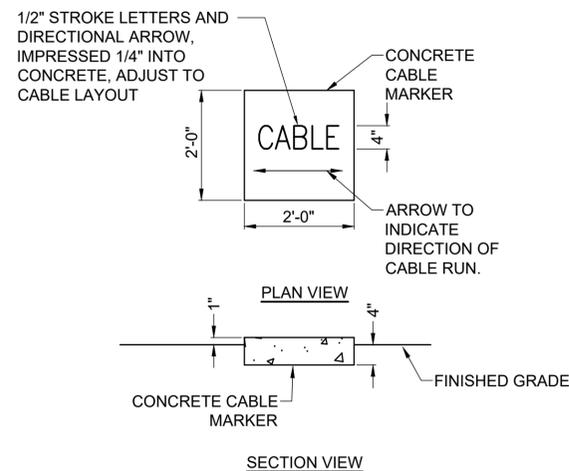


TURF CABLE MARKERS
"NOT TO SCALE"

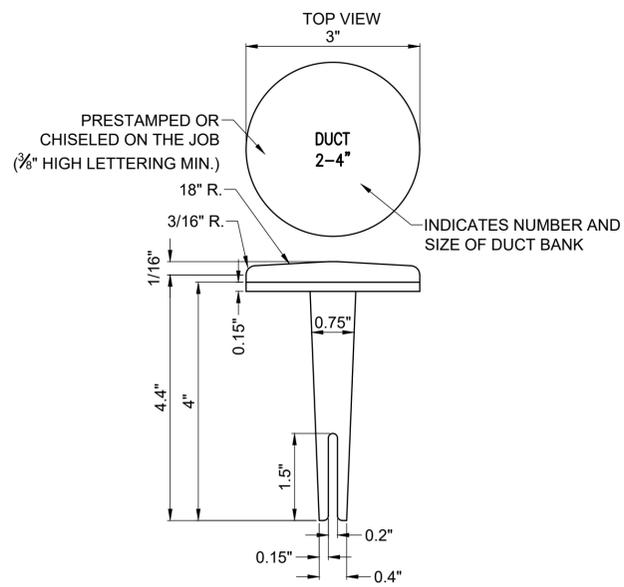


BITUMINOUS PAVEMENT DUCT MARKERS
"NOT TO SCALE"

NOTE:

- TOP OF MARKER SHALL BE FLUSH WITH FINISHED PAVEMENT SURFACE. MARKER MAY BE INSTALLED IN A DRILLED HOLE AND SECURED WITH EPOXY GLUE
- BRASS DUCT MARKERS ARE AVAILABLE FROM BERNTSEN INTERNATIONAL INC., P.O. BOX 8670, MADISON, WI. 53708-8670, PHONE: 1-877-959-8556, SURV-KAP, 3225 E. 47TH ST., TUCSON, AZ 85713, PHONE: (502)-622-6011, OR OTHER EQUIVALENT MANUFACTURERS.

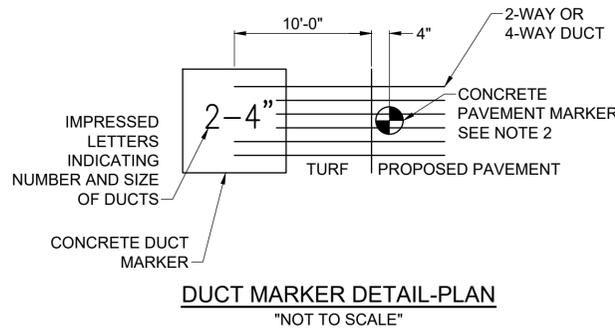

DUCT MARKER DETAIL-PLAN
"NOT TO SCALE"

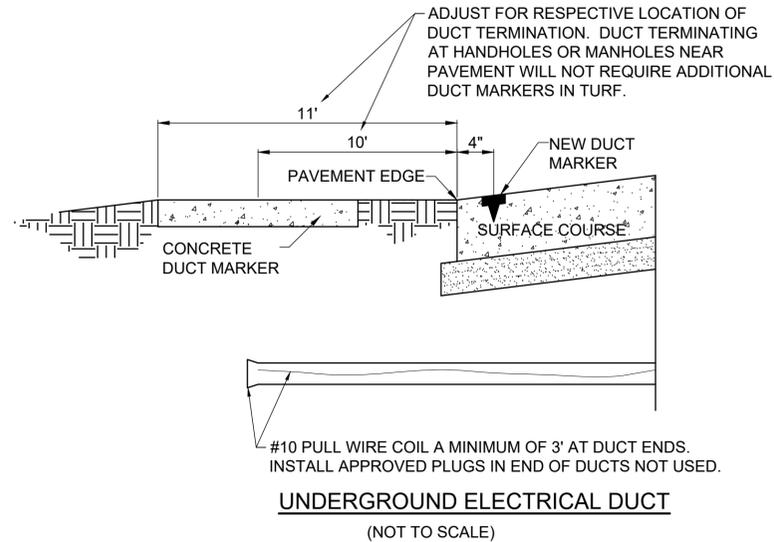

UNDERGROUND ELECTRICAL DUCT
"NOT TO SCALE"

CABLE & DUCT MARKER NOTES:

- THE COST OF ALL TURF AND PAVEMENT DUCT MARKERS SHALL BE INCIDENTAL TO THE DUCT. THE COST OF ALL CABLE MARKERS SHALL BE INCIDENTAL TO THE CABLE.
- BITUMINOUS PAVEMENT DUCT MARKER AND CONCRETE DUCT MARKER TO BE PROVIDED AT EACH END OF EACH DUCT AS SHOWN ON THE LOCATION PLAN. FOR CONCRETE PAVEMENT, THE LETTER "D" SHALL BE IMPRESSED IN THE PAVEMENT INSTEAD OF THE MARKER. THE LETTER SHALL BE INFORMED AS DESCRIBED IN NOTE 4.
- UNDERGROUND CABLE RUNS MUST BE IDENTIFIED BY CABLE MARKERS AT 200 FEET (61 M) MAXIMUM SPACING WITH AN ADDITIONAL MARKER AT EACH CHANGE OF DIRECTION OF THE CABLE RUN. CABLE MARKERS MUST BE INSTALLED ABOVE THE CABLE. CABLE MARKERS ARE NOT REQUIRED FOR CABLE RUNS BETWEEN RUNWAY/TAXIWAY EDGE LIGHTS.
- CONCRETE CABLE MARKERS AND DUCT MARKERS SHALL HAVE LETTERS 4" HIGH, 3" WIDE WITH WIDTH OF STROKE 1/2" AND 1/4" DEEP. ALL LETTERS, NUMBERS AND ARROWS TO BE IMPRESSED.
- EMPLOY THE FOLLOWING METHODS WHERE ADDITIONAL SPACE TO FIT THE LEGEND IS REQUIRED:
 - REDUCE LETTER SIZE TO 3" HIGH, 2" WIDE.
 - INCREASE THE MARKER SIZE TO 30" X 30".
 - PROVIDE ADDITIONAL MARKERS PLACED SIDE BY SIDE
- TURF DUCT MARKERS ARE NOT REQUIRED AT PAVEMENT CROSSINGS WHERE DUCTS TERMINATE IN HANDHOLES, OR JUNCTION STRUCTURES.
- LOCATION OF ALL DIRECT EARTH BURIAL UNDERGROUND CABLE SPLICE/CONNECTIONS, EXCEPT THOSE AT ISOLATION TRANSFORMERS, MUST BE IDENTIFIED BY SPLICE MARKERS. SPLICE MARKERS MUST BE PLACED ABOVE THE SPLICE/CONNECTIONS. DIRECT EARTH BURIAL UNDERGROUND CABLE SPLICES SHALL BE AVOIDED WHERE POSSIBLE. CABLE SPLICES SHALL BE LOCATED IN SPLICE CANS, LIGHT BASES, HANDHOLES, MANHOLES, OR OTHER JUNCTION STRUCTURES UNLESS OTHERWISE APPROVED BY THE PROJECT ENGINEER.
- THE CABLE AND SPLICE MARKERS MUST IDENTIFY THE CIRCUITS TO WHICH THE CABLES BELONG. FOR EXAMPLE: RWY 4-22, PAPI-4, PAPI-22.
- LOCATIONS OF ENDS OF ALL UNDERGROUND DUCTS MUST BE IDENTIFIED BY DUCT MARKERS.

INSTALL RUNWAY END IDENTIFIER LIGHTS ON RUNWAY END 13

SBG: 3-17-SBGp-TBD

IDA No: C75-5140


Contract No. MA035

NO.	DATE	DESCRIPTION		
		DES	DWN	REV

ISSUE: AUGUST, 16 2024
PROJECT NO: 23A1045
CAD FILE: E-505-DETL.DWG
DESIGN BY: KNL 05/19/2024
DRAWN BY: JAP 05/02/2024
REVIEWED BY: KNL 6/10/2024

SHEET TITLE

CABLE AND DUCT MARKER DETAILS

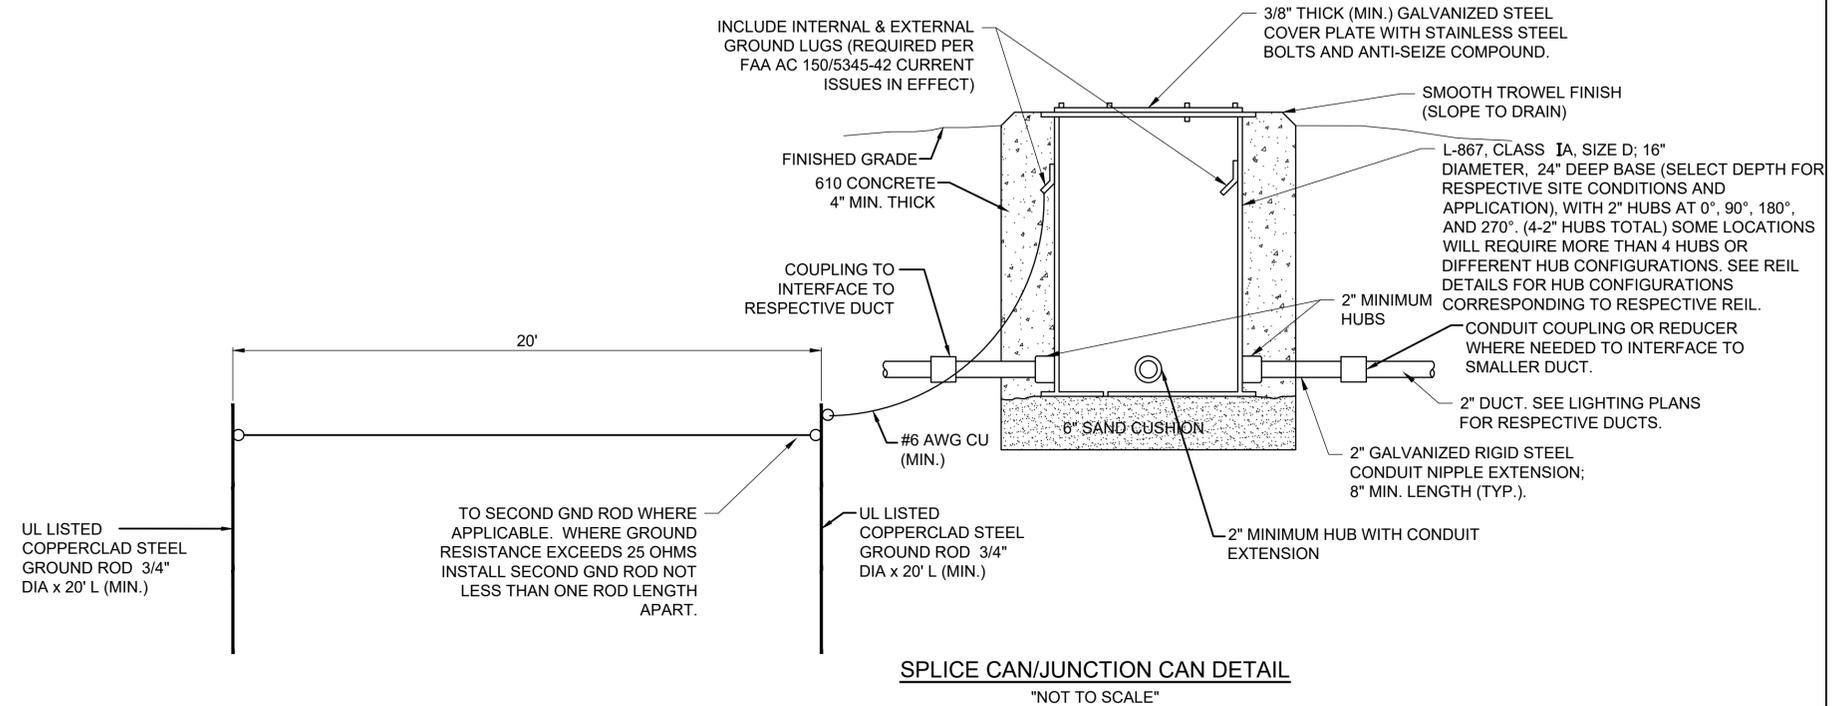

SPLICE CAN/JUNCTION CAN DETAIL

"NOT TO SCALE"

NOTES FOR SPLICE CAN/JUNCTION CAN DETAIL:

- SPLICE CANS SHALL CONFORM TO THE REQUIREMENTS OF FAA AC 150/5345-42 (CURRENT ISSUES IN EFFECT), FOR TYPE L-867, CLASS IA, SIZE D, (16 IN. NOMINAL DIAMETER), AND 24 IN. DEEP AND/OR AS DETAILED ON THE PLANS. EACH SPLICE CAN SHALL INCLUDE INTERNAL AND EXTERNAL GROUND LUGS TO ACCOMMODATE THE RESPECTIVE APPLICATIONS. SPLICE CANS AND/OR JUNCTION CANS SHALL HAVE GALVANIZED STEEL COVERS, 3/8-INCH THICK (MINIMUM), WITH STAINLESS STEEL BOLTS.
- FOR THE PURPOSE OF ENHANCING SAFETY, EACH BASE MUST HAVE INSTALLED, BY THE MANUFACTURER, AN INTERNAL AND EXTERNAL GROUND STRAP THAT IS AVAILABLE FOR THE PURPOSE OF ATTACHING A GROUND LUG THAT IS CONNECTED TO AN EARTH GROUND OR A SAFETY GROUND CONDUCTOR INSTALLED WITH THE RESPECTIVE CIRCUIT. FOR AIRPORT PROJECTS RECEIVING FEDERAL FUNDS THIS REQUIREMENT IS MANDATORY PER FAA AC 150/5345-42 (CURRENT ISSUES IN EFFECT).
- APPLY AN OXIDE-INHIBITING, ANTI-SEIZING COMPOUND TO ALL SCREWS, NUTS, AND ALL PLACES WHERE METAL COMES INTO CONTACT WITH METAL.
- THE CONCRETE USED IN THE CONSTRUCTION OF THE BASES FOR THE AIRFIELD LIGHTING CANS SHALL BE IN ACCORDANCE WITH ITEM 610 STRUCTURAL PORTLAND CEMENT CONCRETE.
- LIDS FOR THE SPLICE CANS CONTAINING HIGH VOLTAGE AIRFIELD LIGHTING CABLES SHALL INCLUDE MINIMUM 1/2-INCH HIGH LETTERING LABELED "DANGER HIGH VOLTAGE KEEP OUT" TO COMPLY WITH NEC ARTICLE 300.45 "WARNING SIGNS" AND NEC ARTICLE 314.71(E) "SUITABLE COVERS". THIS WILL NEED TO BE COORDINATED WITH THE SPLICE CAN MANUFACTURER.
- LIDS FOR THE SPLICE CANS CONTAINING LOW VOLTAGE CABLES (RATED 600 VOLTS AND BELOW) WILL BE ACCEPTABLE TO USE BLANK COVERS.
- PROVIDE NEW GROUND RODS FOR EXISTING SPLICE CANS DESIGNATED FOR RELOCATION.
- PROVIDE ADEQUATE SLACK CABLE AT SPLICE CANS/JUNCTION CANS TO PERFORM SPLICES OUTSIDE OF THE SPLICE CAN.

INSTALL RUNWAY END IDENTIFIER LIGHTS ON RUNWAY END 13

SBG: 3-17-SBGp-TBD

IDA No: C75-5140

Contract No. MA035

NO.	DATE	DESCRIPTION		
		DES	DWN	REV

ISSUE: AUGUST, 16 2024
PROJECT NO: 23A1045
CAD FILE: E-506-DETL.DWG
DESIGN BY: KNL 05/19/2024
DRAWN BY: JAP 05/02/2024
REVIEWED BY: KNL 6/10/2024

SHEET TITLE

SPLICE CAN DETAIL



GENERAL NOTES

1. ALL ELECTRICAL EQUIPMENT SHALL BE INSTALLED IN CONFORMANCE WITH NFPA 70 - NATIONAL ELECTRICAL CODE (NEC) MOST CURRENT ISSUE IN FORCE, THE RESPECTIVE EQUIPMENT MANUFACTURER'S DIRECTIONS AND ALL OTHER APPLICABLE LOCAL CODES, LAWS, ORDINANCES, AND REQUIREMENTS IN FORCE. ANY INSTALLATIONS WHICH VOID THE U.L. LISTING, INTERTEK TESTING SERVICES VERIFICATION/ETL LISTING (OR OTHER THIRD PARTY LISTING) AND/OR THE MANUFACTURER'S WARRANTY OF A DEVICE WILL NOT BE PERMITTED.
2. CONTRACTOR SHALL KEEP A COPY OF THE LATEST NEC IN FORCE ON SITE AT ALL TIMES DURING CONSTRUCTION FOR USE AS A REFERENCE.
3. CONTRACTOR SHALL COORDINATE WORK AND ANY POWER OUTAGES AND/OR SHUT DOWN OF SYSTEMS WITH THE RESPECTIVE FACILITY OWNER PERSONNEL AND THE AIRPORT MANAGER/DIRECTOR. ONCE SHUT DOWN, THE CIRCUITS SHALL BE LABELED AS SUCH TO PREVENT ACCIDENTAL ENERGIZING OF THE RESPECTIVE CIRCUITS. ALL PERSONNEL SHALL FOLLOW U.S. DEPARTMENT OF LABOR OCCUPATIONAL SAFETY & HEALTH ADMINISTRATION (OSHA) 29 CFR PART 1910 OCCUPATIONAL SAFETY & HEALTH STANDARDS FOR ELECTRICAL SAFETY AND LOCKOUT/TAGOUT PROCEDURES INCLUDING, BUT NOT LIMITED TO, 29 CFR SECTION 1910.147 THE CONTROL OF HAZARDOUS ENERGY (LOCKOUT/TAGOUT).
4. THE CONTRACTOR SHALL ASCERTAIN THAT ALL LIGHTING SYSTEM COMPONENTS FURNISHED BY HIM, INCLUDING FAA APPROVED EQUIPMENT, ARE COMPATIBLE IN ALL RESPECTS WITH EACH OTHER AND THE REMAINDER OF THE NEW/EXISTING SYSTEM. ANY NONCOMPATIBLE COMPONENTS FURNISHED BY THIS CONTRACTOR SHALL BE REPLACED BY HIM AT NO ADDITIONAL COST TO THE AIRPORT SPONSOR WITH A SIMILAR UNIT, APPROVED BY THE ENGINEER (DIFFERENT MODEL OR DIFFERENT MANUFACTURER) THAT IS COMPATIBLE WITH THE REMAINDER OF THE AIRPORT LIGHTING SYSTEM.
5. IN CASE THE CONTRACTOR ELECTS TO FURNISH AND INSTALL AIRPORT LIGHTING EQUIPMENT REQUIRING ADDITIONAL WIRING, TRANSFORMERS, ADAPTORS, MOUNTINGS, ETC., TO THOSE SHOWN ON THE DRAWINGS AND/OR LISTED IN THE SPECIFICATION, ANY COST FOR THESE ITEMS SHALL BE INCIDENTAL TO THE EQUIPMENT COST.
6. THE CONTRACTOR INSTALLED EQUIPMENT (INCLUDING FAA APPROVED) SHALL NOT GENERATE ANY ELECTROMAGNETIC INTERFERENCE IN THE EXISTING AND/OR NEW COMMUNICATIONS, WEATHER, AIR NAVIGATION, AND AIR TRAFFIC CONTROL EQUIPMENT. ANY EQUIPMENT GENERATING SUCH INTERFERENCE SHALL BE REPLACED BY THE CONTRACTOR AT NO ADDITIONAL COST WITH THE EQUIPMENT MEETING THE APPLICABLE SPECIFICATIONS AND NOT GENERATING ANY INTERFERENCE.
7. WHEN A SPECIFIC TYPE, STYLE, CLASS, ETC. OF FAA APPROVED EQUIPMENT IS SPECIFIED ONLY THAT TYPE, STYLE, CLASS, WILL BE ACCEPTABLE, EVEN THOUGH EQUIPMENT OF OTHER TYPES STYLES, CLASSES, ETC. MAY BE APPROVED.
8. ANY AND ALL INSTRUCTIONS FROM THE RESIDENT ENGINEER/RESIDENT TECHNICIAN TO THE CONTRACTOR REGARDING CHANGES IN OR DEVIATIONS FROM THE PLANS AND SPECIFICATIONS SHALL BE IN WRITING WITH COPIES SENT TO THE AIRPORT SPONSOR AND THE ILLINOIS DEPARTMENT OF TRANSPORTATION DIVISION OF AERONAUTICS. THE CONTRACTOR SHALL NOT ACCEPT ANY VERBAL INSTRUCTIONS FROM THE RESIDENT ENGINEER/RESIDENT TECHNICIAN REGARDING ANY CHANGES FROM THE PLANS AND SPECIFICATIONS.
9. A MINIMUM OF THREE COPIES OF THE INSTRUCTION BOOK SHALL BE SUPPLIED WITH EACH DIFFERENT TYPE OF EQUIPMENT. THE BOOKS DESCRIBING A MORE SOPHISTICATED TYPE OF EQUIPMENT, SUCH AS REGULATORS, PAPI, REIL, ETC. AS A MINIMUM SHALL CONTAIN THE FOLLOWING:
 - A. A DETAILED DESCRIPTION OF THE OVERALL EQUIPMENT AND ITS INDIVIDUAL COMPONENTS.
 - B. THEORY OF OPERATION INCLUDING THE FUNCTION OF EACH COMPONENT.
 - C. INSTALLATION INSTRUCTION.
 - D. START-UP INSTRUCTIONS.
 - E. PREVENTATIVE MAINTENANCE REQUIREMENTS.
 - F. CHART FOR TROUBLE-SHOOTING.
 - G. COMPLETE POWER AND CONTROL DETAILED WIRING DIAGRAM(S), SHOWING EACH CONDUCTOR/CONNECTION/COMPONENT - "BLACK" BOXES ARE NOT ACCEPTABLE. THE DIAGRAM OF THE NARRATIVE SHALL SHOW VOLTAGE/CURRENTS/WAVE SHAPES AT STRATEGIC LOCATIONS TO BE USED WHEN CHECKING AND/OR TROUBLE-SHOOTING THE EQUIPMENT. WHEN THE EQUIPMENT HAS SEVERAL MODES OF OPERATION, SUCH AS SEVERAL BRIGHTNESS STEPS, THESE PARAMETERS SHALL BE INDICATED FOR ALL DIFFERENT MODES.
 - H. PARTS LIST WHICH WILL INCLUDE ALL MAJOR AND MINOR COMPONENTS SUCH AS RESISTORS, DIODES, ETC. IT SHALL INCLUDE A COMPLETE NOMENCLATURE OF EACH COMPONENT AND, IF APPLICABLE, THE NAME OF ITS MANUFACTURER AND THE CATALOG NUMBER.
 - I. SAFETY INSTRUCTIONS.

POWER AND CONTROL NOTES

1. PROVIDE LEGEND PLATES FOR ALL ELECTRICAL EQUIPMENT TO IDENTIFY FUNCTION, CIRCUIT VOLTAGE AND PHASE. WHERE THE EQUIPMENT CONTAINS FUSES, ALSO IDENTIFY THE FUSE OR FUSE LINK AMPERE RATING. WHERE THE EQUIPMENT DOES NOT HAVE SUFFICIENT AREA TO INSTALL LEGEND PLATES, THE LEGEND PLATES SHALL BE INSTALLED ON THE WALL NEXT TO THE UNIT. LEGEND PLATES SHALL BE WEATHERPROOF ENGRAVED PLASTIC OR PHENOLIC MATERIAL, 1/4" HIGH BLACK LETTERS ON A WHITE BACKGROUND UNLESS NOTED OTHERWISE. SECURE WITH WEATHERPROOF ADHESIVE AND MACHINE SCREWS. FURNISH ADDITIONAL LEGEND PLATES WHERE REQUIRED BY CODE, FOR ADDITIONAL EQUIPMENT, AS DETAILED HEREIN ON THE PLANS, AND AS NOTED IN THE SPECIAL PROVISION SPECIFICATIONS.
2. COLOR CODE ALL PHASE WIRING BY THE USE OF COLORED WIRE INSULATION AND/OR COLORED TAPE. WHERE TAPE IS USED, THE WIRE INSULATION SHALL BE BLACK. BLACK AND RED SHALL BE USED FOR PHASE CONDUCTORS ON 120/240VAC SINGLE-PHASE, THREE WIRE SYSTEMS AND BLACK, RED AND BLUE SHALL BE USED FOR PHASE CONDUCTORS ON 208/120VAC THREE-PHASE, FOUR WIRE SYSTEMS. NEUTRAL CONDUCTORS, SIZE NO. 6 AWG OR SMALLER, SHALL BE IDENTIFIED BY A CONTINUOUS WHITE OR NATURAL GRAY OUTER FINISH ALONG ITS ENTIRE LENGTH. NEUTRAL CONDUCTORS LARGER THAN NO. 6 AWG SHALL BE IDENTIFIED EITHER BY A CONTINUOUS WHITE OR NATURAL GRAY OUTER FINISH ALONG ITS ENTIRE LENGTH OR BY THE USE OF WHITE TAPE AT ITS TERMINATIONS AND INSIDE ACCESSIBLE WIREWAYS. INSULATED GROUND CONDUCTORS SHALL HAVE GREEN COLORED INSULATION FOR ALL CONDUCTOR SIZES (AWG OR KCMIL).
3. ALL BRANCH CIRCUIT CONDUCTORS CONNECTED TO A PARTICULAR PHASE SHALL BE IDENTIFIED WITH THE SAME COLOR. THE COLOR CODING SHALL BE EXTENDED TO THE POINT OF UTILIZATION.
4. IN CONTROL WIRING THE SAME COLOR SHALL BE USED THROUGHOUT THE SYSTEM FOR THE SAME FUNCTION, SUCH AS 10%, 30%, 100% BRIGHTNESS CONTROL, ETC.
5. LOW VOLTAGE (600 V.) AND HIGH VOLTAGE (5000 V.) CONDUCTORS SHALL BE INSTALLED IN SEPARATE WIREWAYS.
6. NEATLY LACE WIRING IN DISTRIBUTION PANELS, WIREWAYS, SWITCHES AND JUNCTION/PULL BOXES.
7. THE MINIMUM SIZE OF PULL/JUNCTION BOXES, REGARDLESS OF THE QUANTITY AND SIZE OF THE CONDUCTORS SHOWN, SHALL BE AS FOLLOWS:
 - A. IN STRAIGHT PULLS THE LENGTH OF THE BOX SHALL NOT BE LESS THAN EIGHT TIMES THE TRADE DIAMETER OF THE LARGER CONDUIT. THE TOTAL AREA (INCLUDING THE CONDUIT CROSS-SECTIONAL AREA) OF A BOX END SHALL BE AT LEAST 3 TIMES GREATER THAN THE TOTAL TRADE CROSS-SECTIONAL AREA OF THE CONDUITS TERMINATING AT THE END.
 - B. IN ANGLE PULLS OR 'U' PULLS THE DISTANCE BETWEEN EACH CONDUIT ENTRY INSIDE THE BOX AND THE OPPOSITE WALL OF THE BOX SHALL NOT BE LESS THAN SIX (6) TIMES THE TRADE DIAMETER OF THE LARGEST CONDUIT. THIS DISTANCE SHALL BE INCREASED FOR ADDITIONAL ENTRIES BY THE AMOUNT OF THE SUM OF THE DIAMETERS OF ALL OTHER CONDUIT ENTRIES ON THE SAME WALL AS THE BOX. THE DISTANCE BETWEEN CONDUIT ENTRIES ENCLOSING THE SAME CONDUCTOR SHALL NOT BE LESS THAN SIX TIMES THE TRADE DIAMETER OF THE LARGEST CONDUIT.
8. A RUN OF CONDUIT BETWEEN TERMINATIONS AT EQUIPMENT ENCLOSURES, SQUARE DUCTS AND PULL/JUNCTION BOXES, SHALL NOT CONTAIN MORE THAN THE EQUIVALENT OF FOUR QUARTER BENDS (360 DEGREES TOTAL), INCLUDING THOSE BENDS LOCATED IMMEDIATELY AT THE TERMINATIONS. CAST, CONDUIT TYPE OUTLETS SHALL NOT BE TREATED AS PULL/JUNCTION BOXES.
9. EQUIPMENT CABINETS SHALL NOT BE USED AS PULL/JUNCTION BOXES. ONLY WIRING TERMINATING AT THE EQUIPMENT SHALL BE BROUGHT INTO THESE ENCLOSURES.
10. SPLICES AND JUNCTION POINTS SHALL BE PERMITTED ONLY IN JUNCTION BOXES, DUCTS EQUIPPED WITH REMOVABLE COVERS, AND AT EASILY ACCESSIBLE LOCATIONS.
11. CIRCUIT BREAKERS IN POWER DISTRIBUTION PANEL(S) SHALL BE THERMAL-MAGNETIC MOLDED CASE, PERMANENT TRIP WITH 100 AMPERE, MINIMUM FRAME.
12. DUAL LUGS SHALL BE USED WHERE TWO (2) WIRES, SIZE NO. 6 OR LARGER, ARE TO BE CONNECTED TO THE SAME TERMINAL.
13. ALL INTERIOR WALL MOUNTED EQUIPMENT ENCLOSURES SHALL BE MOUNTED ON HOT DIPPED GALVANIZED STEEL STRUT SUPPORT, OR STAINLESS STEEL STRUT SUPPORT, WITH CORROSION RESISTANT HARDWARE. PROVIDE ZINC RICH PAINT APPLIED TO FIELD CUTS OF GALVANIZED STEEL SUPPORT TO MINIMIZE THE POTENTIAL FOR CORROSION PER THE RESPECTIVE STRUT SUPPORT MANUFACTURER'S RECOMENTATIONS.
14. SUPPORT FOR EXTERIOR MOUNTED EQUIPMENT SHALL USE STAINLESS STEEL STRUT SUPPORT WITH STAINLESS STEEL HARDWARE.
15. CONDUITS FOR ELECTRIC SERVICE ENTRANCE AND FEEDERS SHALL BE AS DETAILED HEREIN ON THE PLANS. WHERE GALVANIZED RIGID STEEL CONDUIT IS SPECIFIED IT SHALL HAVE THREADED FITTINGS. SET SCREW TYPE FITTINGS WILL NOT BE ACCEPTABLE. CONDUITS FOR UNDERGROUND APPLICATIONS SHALL BE AS DETAILED HEREIN. CONDUITS FOR GROUNDING ELECTRODE CONDUCTORS OR INDIVIDUAL GROUNDING CONDUCTORS SHALL BE SCHEDULE 40 OR SCHEDULE 80 PVC.
16. PROVIDE LIQUID TIGHT FLEXIBLE METAL CONDUIT AT CONNECTIONS TO EQUIPMENT SUBJECT TO VIBRATION OR WHERE FLEXIBILITY IS REQUIRED. LIQUID TIGHT FLEXIBLE METAL CONDUIT AND ASSOCIATED FITTINGS SHALL BE U.L. LISTED TO MEET THE REQUIREMENTS OF NEC 350.6, SUITABLE FOR GROUNDING, SUNLIGHT RESISTANT, AND RESISTANT TO OIL, GASOLINE, AND GREASE. LIQUID TIGHT FLEXIBLE METAL CONDUIT THAT IS USED FOR FLEXIBILITY (INCLUDING CONNECTIONS TO MOTORS, TRANSFORMERS, & CONSTANT CURRENT REGULATORS) SHALL REQUIRE AN EXTERNAL BONDING JUMPER OR INTERNAL EQUIPMENT GROUNDING CONDUCTOR PER NEC 350.60. DO NOT INSTALL LIQUID TIGHT FLEXIBLE METAL CONDUIT THAT IS NOT UL LISTED. CONFIRM LIQUID-TIGHT FLEXIBLE METAL CONDUIT BEARS THE UL LABEL PRIOR TO INSTALLING IT.
17. UNLESS OTHERWISE SHOWN, ALL EXPOSED CONDUITS SHALL BE RUN PARALLEL TO OR AT RIGHT ANGLES WITH THE LINES OF THE STRUCTURE.
18. ALL STEEL CONDUITS, FITTINGS, NUTS, BOLTS, ETC. SHALL BE GALVANIZED.
19. USE CONDUIT BUSHINGS AT EACH CONDUIT TERMINATION. WHERE NO. 4 AWG OR LARGER UNDERGROUND WIRE IS INSTALLED, USE INSULATED BUSHINGS.
20. USE DOUBLE LOCK NUTS AT EACH CONDUIT TERMINATION.
21. WRAP ALL PRIMARY AND SECONDARY POWER CONNECTIONS WITH SUFFICIENT LAYERS OF HIGH VOLTAGE ELECTRICAL INSULATING TAPE (RUBBER SPLICING TAPE SUITABLE FOR PRIMARY ELECTRICAL INSULATION FOR SPLICING CABLE FROM 600 VOLTS TO 69,000 VOLTS) AND COVER WITH VINYL ELECTRICAL TAPE (ALL-WEATHER VINYL INSULATING TAPE SUITABLE FOR PROTECTIVE JACKETING FOR HIGH-VOLTAGE CABLE SPLICES AND REPAIRS) FOR FULL VALUE OF CABLE INSULATION VOLTAGE. PER ILLINOIS STANDARD SPECIFICATIONS FOR CONSTRUCTION OF AIRPORTS ITEM 108, ITEM 125 AND FAA AC 150/5370-10H ITEM L-108, HIGH VOLTAGE ELECTRICAL INSULATING TAPE SHALL BE 3M SCOTCH 130C (2 INCHES WIDE) OR APPROVED EQUIVALENT, AND VINYL ELECTRICAL TAPE SHALL BE 3M SCOTCH 88 (1.5 INCHES WIDE) OR APPROVED EQUIVALENT. TAPES MUST BE RATED SUITABLE FOR THE APPLICATION.
22. UNLESS OTHERWISE NOTED, ALL SINGLE CONDUCTOR CONTROL WIRING SHALL BE NO. 12 AWG. COPPER MINIMUM.
23. THE FOLLOWING SHALL APPLY TO RELAY/CONTACTOR PANELS/ENCLOSURES:
 - A. FOR INTERIOR LOCATIONS ALL COMPONENTS SHALL BE MOUNTED IN NEMA 12 (DUST TIGHT) ENCLOSURE(S) WITH VERTICALLY HINGED COVERS. FOR EXTERIOR/OUTDOOR LOCATIONS ALL COMPONENTS SHALL BE MOUNTED IN NEMA 4X STAINLESS STEEL ENCLOSURE(S) WITH VERTICALLY HINGED COVERS. ALL CONDUIT ENTRIES INTO NEMA 4, 4X ENCLOSURES SHALL HAVE NEMA 4 HUBS LISTED SUITABLE FOR THE RESPECTIVE ENCLOSURE TO MAINTAIN THE NEMA 4, 4X RATING OF THE ENCLOSURE.
 - B. THE ENCLOSURE(S) SHALL HAVE AMPLE SPACE FOR THE CIRCUIT COMPONENTS, TERMINAL BLOCKS AND INCOMING AND INTERNAL WIRING.
 - C. ALL CONTROL CONDUCTOR TERMINATIONS SHALL BE OF THE OPEN-EYE CONNECTOR/SCREW TYPE. SOLDERED CLOSED-EYE TERMINATIONS, OR TERMINATIONS WITHOUT CONNECTORS ARE NOT ACCEPTABLE.
 - D. WHEN THE ENCLOSURE COVER IS OPENED, ALL CIRCUIT COMPONENTS, WIRING AND TERMINALS SHALL BE EXPOSED AND ACCESSIBLE WITHOUT REMOVAL OF ANY PANELS, COVERS, ETC., EXCEPT THOSE COVERING HIGH VOLTAGE COMPONENTS.
 - E. ACCESS TO, OR REMOVAL OF A CIRCUIT COMPONENT OR TERMINAL BLOCK WILL NOT REQUIRE THE REMOVAL OF ANY OTHER CIRCUIT COMPONENT OR TERMINAL BLOCK.
 - F. EACH CIRCUIT COMPONENT SHALL BE CLEARLY IDENTIFIED INDICATING ITS CORRESPONDING NUMBER SHOWN ON THE DRAWINGS AND ITS FUNCTION.
 - G. A COMPLETE WIRING DIAGRAM SHALL BE MOUNTED ON THE INSIDE OF THE COVER. THE DIAGRAM SHALL REPRESENT EACH CONDUCTOR BY A SEPARATE LINE.
 - H. THE DIAGRAM SHALL IDENTIFY EACH CIRCUIT COMPONENT AN NUMBERING AND COLOR OF EACH TERMINAL CONDUCTOR AND TERMINAL.
 - I. ALL WIRING SHALL BE NEATLY TRAINED AND LACED.
 - J. MINIMUM WIRE SIZE SHALL BE NO. 12 AWG.
24. FURNISH & INSTALL A WEATHERPROOF WARNING LABEL FOR EACH METER SOCKET, SERVICE DISCONNECT, SAFETY SWITCH, CUTOUT, PANELBOARD, & CONTROL PANEL TO WARN PERSONS OF POTENTIAL ELECTRIC ARC FLASH HAZARDS, PER THE REQUIREMENTS OF NEC 110.16 "ARC FLASH HAZARD WARNING".

INSTALL RUNWAY END IDENTIFIER LIGHTS ON RUNWAY END 13

SBG: 3-17-SBG-P-TBD

IDA No: C75-5140

Contract No. MA035

NO.	DATE	DESCRIPTION		
		DES	DWN	REV

ISSUE: AUGUST, 16 2024
PROJECT NO: 23A1045
CAD FILE: E-001-NOTES.DWG
DESIGN BY: KNL 05/19/2024
DRAWN BY: JAP 05/02/2024
REVIEWED BY: KNL 6/10/2024

SHEET TITLE

ELECTRICAL NOTES SHEET 1



INSTALL RUNWAY END IDENTIFIER LIGHTS ON RUNWAY END 13

SBG: 3-17-SBGp-TBD

IDA No: C75-5140

Contract No. MA035

NO.	DATE	DESCRIPTION		
		DES	DWN	REV

ISSUE: AUGUST, 16 2024
PROJECT NO: 23A1045
CAD FILE: E-002-NOTES.DWG
DESIGN BY: KNL 05/19/2024
DRAWN BY: JAP 05/02/2024
REVIEWED BY: KNL 6/10/2024

SHEET TITLE

ELECTRICAL NOTES SHEET 2


AIRFIELD LIGHTING NOTES

1. UNLESS OTHERWISE NOTED, ALL UNDERGROUND AIRFIELD LIGHTING SERIES CIRCUIT CONDUCTORS WHETHER DEB OR IN DUCT/CONDUIT SHALL BE FAA APPROVED 5000 VOLT L-824 TYPE. ALL UNDERGROUND FIELD POWER LOW VOLTAGE (600 VOLT & BELOW) CIRCUIT CONDUCTORS WHETHER DEB OR IN DUCT/CONDUIT SHALL BE UL LISTED 600 VOLT, TYPE XLP-USE-2 COPPER CONDUCTORS. CONDUCTOR SIZES SHALL BE AS SPECIFIED, HEREIN.
2. NO COMPONENTS OF PRIMARY CIRCUIT SUCH AS CABLE, CONNECTORS AND TRANSFORMERS SHALL BE BROUGHT ABOVE GROUND AT EDGE LIGHTS, SIGNS, REIL, PAPI, ETC.
3. THERE SHALL BE NO EXPOSED POWER/CONTROL CABLES BETWEEN THE POINT WHERE THEY LEAVE THE UNDERGROUND (DEB OR L-867 BASES) AND WHERE THEY ENTER THE EQUIPMENT (SUCH AS TAXIWAY SIGNS, PAPI, REIL, ETC.) ENCLOSURES. THESE CABLES SHALL BE ENCLOSED IN RIGID CONDUIT OR IN FLEXIBLE, WATERTIGHT CONDUIT WITH BREAKABLE COUPLING(S) AT THE GRADE OR THE HOUSING COVER, AS SHOWN IN APPLICABLE DETAILS.
4. THE JOINTS OF THE L-823 PRIMARY CONNECTORS SHALL BE WRAPPED WITH AT LEAST ONE LAYER OF RUBBER OR SYNTHETIC RUBBER TAPE AND ONE LAYER OF PLASTIC TAPE, ONE-HALF LAPPED, EXTENDING AT LEAST 1-1/2 INCHES ON EACH SIDE OF THE JOINT, AS SHOWN ON AIRFIELD LIGHTING CABLE SPLICE DETAILS.
5. THE CABLE ENTRANCE INTO THE FIELD-ATTACHED L-823 CONNECTORS SHALL BE ENCLOSED BY A HEAT-SHRINKABLE TUBING WITH CONTINUOUS INTERNAL ADHESIVE, AS SHOWN ON AIRFIELD LIGHTING CABLE SPLICE DETAILS.
6. L-823 TYPE II, TWO-CONDUCTOR SECONDARY CONNECTORS SHALL BE CLASS 'A' (FACTORY MOLDED).
7. THERE SHALL BE NO SPLICES IN THE SECONDARY CABLE(S) WITHIN THE STEMS OF A RUNWAY/TAXIWAY EDGE/THRESHOLD LIGHTING FIXTURE AND THE WIREWAYS LEADING TO TAXIWAY SIGNS AND PAPI/REIL EQUIPMENT.
8. ELECTRICAL INSULATING GREASE SHALL BE APPLIED WITHIN THE L-823, SECONDARY, TWO CONDUCTOR CONNECTORS TO PREVENT WATER ENTRANCE. THESE CONNECTORS SHALL NOT BE TAPED.
9. DEB ISOLATION TRANSFORMERS SHALL BE BURIED AT A DEPTH OF TEN (10") INCHES ON A LINE CROSSING THE LIGHT AND PERPENDICULAR TO THE RUNWAY/TAXIWAY CENTERLINE AT A LOCATION TWELVE (12") INCHES FROM THE LIGHT OPPOSITE FROM THE RUNWAY/TAXIWAY.
10. A SLACK OF THREE (3') FEET, MINIMUM, PLUS DEPTH OF BASE CAN (IF APPLICABLE), SHALL BE PROVIDED IN THE PRIMARY CABLE AT EACH TRANSFORMER/CONNECTOR TERMINATION. AT STAKE-MOUNTED LIGHTS, THE SLACK SHALL BE LOOSELY COILED IMMEDIATELY BELOW THE ISOLATION TRANSFORMER. THERE SHALL BE NO ADDITIONAL PAYMENT FOR CABLE SLACK AND THEREFORE THE QUANTITY OF PROPOSED CABLE SLACK HAS NOT BEEN INCLUDED IN THE RESPECTIVE CABLE PAY ITEMS.
11. DIRECTION OF PRIMARY CABLES SHALL BE IDENTIFIED BY COLOR CODING AS FOLLOWS: WHEN FACING LIGHT WITH BACK TO PAVEMENT, CABLE TO THE LEFT IS CODED RED AND CABLE TO RIGHT IS CODED BLUE. THIS APPLIES TO STAKE MOUNTED LIGHTS AND BASE MOUNTED LIGHTS WHERE THE BASE HAS ONLY ONE ENTRANCE.
12. L-867 BASES SHALL BE SIZE B, 24" DEEP, CLASS I, UNLESS OTHERWISE NOTED.
13. BASE MOUNTED BREAKABLE COUPLINGS SHALL NOT HAVE WEEP HOLES TO THE OUTSIDE. PLUGGED UP HOLES SHALL NOT BE ACCEPTABLE. IT SHALL BE A 1/4" DIAMETER, MINIMUM, OR EQUIVALENT OPENING FOR DRAINAGE FROM THE SPACE AROUND THE SECONDARY CONNECTOR INTO THE L-867 BASE.
14. THE ELEVATION OF THE BREAKABLE COUPLING GROOVE SHALL NOT EXCEED 1-1/2" ABOVE THE EDGE OF THE COVER IN CASE OF BASE MOUNTED COUPLINGS, OR THE TOP OF THE STAKE IN CASE OF STAKE MOUNTED COUPLINGS.
15. WHERE THE BREAKABLE COUPLING IS NOT AN INTEGRAL PART OF THE LIGHT FIXTURE STEM OR MOUNTING LEG, A BEAD OF SILICON SEAL SHALL BE APPLIED COMPLETELY AROUND LIGHT STEM OR WIREWAY AT BREAKABLE COUPLING TO PROVIDE A WATERTIGHT SEAL.
16. TOPS OF THE STAKES SUPPORTING LIGHT FIXTURES SHALL BE FLUSH WITH THE SURROUNDING GRADE.
17. PLASTIC LIGHTING FIXTURE COMPONENTS, SUCH AS LAMP HEADS, STEMS, BREAKABLE COUPLINGS, BASE COVERS, BRACKETS, STAKES, SHALL NOT BE ACCEPTABLE.
18. THE TOLERANCE FOR THE HEIGHT OF RUNWAY/TAXIWAY EDGE LIGHTS SHALL BE: ONE (1) INCH. IN CASE OF STAKE MOUNTED LIGHTS, THE SPECIFIED LIGHTING FIXTURE HEIGHT SHALL BE MEASURED BETWEEN THE TOP OF THE STAKE AND THE TOP OF THE LENS. IN CASE OF BASE MOUNTED LIGHTS, THE SPECIFIED LIGHTING FIXTURE HEIGHT SHALL BE MEASURED BETWEEN THE TOP OF THE BASE FLANGE AND THE TOP OF THE LENS, THUS INCLUDING THE BASE COVER, THE FRANGIBLE COUPLING, THE STEM, THE LAMP HOUSING AND THE LENS.
19. THE TOLERANCE FOR THE LATERAL SPACING (LIGHT LANE TO RUNWAY/TAXIWAY CENTERLINE) OF RUNWAY/TAXIWAY EDGE LIGHTS SHALL BE ONE (1) INCH. THIS ALSO APPLIES AT INTERSECTIONS TO LATERAL SPACING BETWEEN LIGHTS OF A RUNWAY/TAXIWAY AND THE INTERSECTING RUNWAY/TAXIWAY.

GROUNDING NOTES FOR REILS

20. ENTRANCES INTO L-867 BASES SHALL HAVE CONDUIT COUPLINGS OR REDUCERS TO INTERFACE UNIT DUCT/CONDUIT TO L-867 BASE HUBS, OR SHALL BE SEALED WITH HEAT SHRINK.
21. GALVANIZED/PAINTED EQUIPMENT/COMPONENT SURFACES SHALL NOT BE DAMAGED BY DRILLING, FILING, ETC. DRAIN HOLES IN METAL TRANSFORMER HOUSINGS SHALL BE MADE BEFORE GALVANIZING.
22. EDGE LIGHT NUMBERING TAGS SHALL BE FACING THE PAVEMENT.
23. CABLE/SPLICE/DUCT MARKERS SHALL BE PRECAST CONCRETE OF THE SIZE SHOWN. LETTERS/NUMBERS/ARROWS FOR THE LEGEND TO BE IMPRESSED INTO THE TOPS OF THE MARKERS SHALL BE PRE-ASSEMBLED AND SECURED IN THE MOLD BEFORE THE CONCRETE IS POURED. LEGEND INSCRIBED BY HAND IN WET CONCRETE SHALL NOT BE ACCEPTABLE.
24. ALL UNDERGROUND CABLE RUNS SHALL BE IDENTIFIED BY CABLE MARKERS AT 200 FEET MAXIMUM SPACING, WITH AN ADDITIONAL MARKER AT EACH CHANGE OF DIRECTION OF THE CABLE RUN. CABLE MARKERS SHALL BE INSTALLED IMMEDIATELY ABOVE THE CABLES.
25. THERE SHALL BE NO SPLICES BETWEEN THE ISOLATION TRANSFORMERS. L-823 CONNECTORS ARE ALLOWED AT TRANSFORMER CONNECTIONS ONLY, UNLESS OTHERWISE SHOWN.
26. APPLY AN OXIDE INHIBITING, ANTI-SEIZING COMPOUND TO ALL SCREWS, NUTS AND BREAKAGE COUPLING THREADS.
27. LOCATIONS OF ENDS OF ALL UNDERGROUND DUCTS SHALL BE IDENTIFIED BY DUCT MARKERS.
28. WHERE A PARALLEL, CONSTANT VOLTAGE PAPI SYSTEM IS PROVIDED, THE "T" SPLICES SHALL BE OF THE CAST TYPE.
29. CONCRETE USED FOR SLABS, FOOTINGS, BACKFILL AROUND TRANSFORMER HOUSINGS, MARKINGS, ETC. SHALL BE 3500 PSI (MINIMUM) AT 14 DAYS, IN ACCORDANCE WITH ITEM 610 STRUCTURAL PORTLAND CEMENT CONCRETE.
30. ALL POWER AND CONTROL CABLES IN MAN/HAND HOLES SHALL BE TAGGED. USE EMBOSSED COPPER STRIPS TO BE ATTACHED AT BOTH ENDS TO THE CABLE BY THE USE OF PLASTIC STRAPS. MINIMUM OF TWO TAGS SHALL BE PROVIDED ON EACH CABLE IN A MAN/HAND HOLE-ONE AT THE CABLE ENTRANCE AND ONE AT THE CABLE EXIT.
31. THE LOCATION, SIZE AND TYPE OF MATERIAL OF EXISTING UNDERGROUND AND/OR ABOVEGROUND UTILITIES INDICATED ON THE PLANS IS NOT REPRESENTED AS BEING ACCURATE, SUFFICIENT OR COMPLETE. NEITHER THE OWNER NOR THE ENGINEER ASSUMES ANY RESPONSIBILITY WHATSOEVER IN RESPECT TO ACCURACY, COMPLETENESS, OR SUFFICIENCY OF THE INFORMATION. THERE IS NO GUARANTEE EITHER EXPRESSED OR IMPLIED, THAT THE LOCATIONS, SIZE AND TYPE OF MATERIAL OF EXISTING UNDERGROUND UTILITIES INDICATED ARE REPRESENTATIVE OF THOSE TO BE ENCOUNTERED IN THE CONSTRUCTION. IT SHALL BE THE CONTRACTOR'S RESPONSIBILITY TO DETERMINE THE ACTUAL LOCATION OF ALL SUCH FACILITIES, INCLUDING SERVICE CONNECTIONS TO UNDERGROUND UTILITIES. PRIOR TO CONSTRUCTION, THE CONTRACTOR SHALL NOTIFY THE UTILITY COMPANIES OF HIS OPERATIONAL PLANS AND SHALL OBTAIN FROM THE RESPECTIVE UTILITY COMPANIES DETAILED INFORMATION AND ASSISTANCE RELATIVE TO THE LOCATION OF THEIR FACILITIES AND THE WORKING SCHEDULE OF THE COMPANIES FOR REMOVAL OR ADJUSTMENT WHERE REQUIRED. IN THE EVENT AN UNEXPECTED UTILITY INTERFERENCE IS ENCOUNTERED DURING CONSTRUCTION, THE CONTRACTOR SHALL IMMEDIATELY NOTIFY THE UTILITY COMPANY OF JURISDICTION. THE OWNER'S REPRESENTATIVE AND/OR THE RESIDENT ENGINEER SHALL ALSO BE IMMEDIATELY NOTIFIED. ANY DAMAGE TO SUCH MAINS AND SERVICES SHALL BE RESTORED TO SERVICE AT ONCE AND PAID FOR BY THE CONTRACTOR AT NO ADDITIONAL COST TO THE CONTRACT. ALL UTILITY CABLES AND LINES SHALL BE LOCATED BY THE RESPECTIVE UTILITY. CONTACT JULIE (JOINT UTILITY LOCATION INFORMATION FOR EXCAVATORS) FOR UTILITY INFORMATION, PHONE: 1-800-892-0123. CONTACT THE FAA (FEDERAL AVIATION ADMINISTRATION) FOR ASSISTANCE IN LOCATING FAA CABLES AND UTILITIES. LOCATION OF FAA POWER, CONTROL AND COMMUNICATION CABLES SHALL BE COORDINATED WITH AND/OR LOCATED BY THE FAA. ALSO CONTACT AIRPORT DIRECTOR/MANAGER AND AIRPORT PERSONNEL FOR ASSISTANCE IN LOCATING UNDERGROUND AIRPORT CABLES AND/OR UTILITIES. ALSO COORDINATE WORK WITH ALL ABOVE GROUND UTILITIES.
32. WHEN PREPARING CABLE FOR SPLICES, THE CONTRACTOR SHALL USE A CABLE STRIPPER/PENCILLER WHENEVER CABLE CONNECTIONS ARE MADE.


1. GROUNDING FOR REILS SHALL CONFORM TO THE RESPECTIVE REIL MANUFACTURER'S INSTALLATION INSTRUCTIONS, AS DETAILED ON THE PLANS, AND AS SPECIFIED HEREIN. FURNISH AND INSTALL TWO 3/4-INCH DIAMETER BY 20-FEET LONG COPPER CLAD GROUND RODS AT EACH REIL UNIT. GROUND RODS SHALL BE BURIED 30" MINIMUM BELOW GRADE. BOND EACH REIL UNIT HOUSING AND THE REIL BASE CAN TO THE RESPECTIVE GROUND ROD IN ACCORDANCE WITH THE MANUFACTURER'S INSTRUCTIONS WITH A #6 AWG BARE SOLID OR STRANDED (PER REIL MANUFACTURER REQUIREMENTS) COPPER GROUNDING ELECTRODE CONDUCTOR. ALL CONNECTIONS TO GROUND RODS SHALL BE EXOTHERMIC WELD AS MANUFACTURED BY CADWELD, THERMOWELD, ULTRAWELD, OR APPROVED EQUAL. CONNECTIONS TO REIL UNIT FRAMES SHALL BE AS RECOMMENDED BY THE MANUFACTURER OR WITH UL LISTED GROUNDING CONNECTORS. CONNECTIONS TO THE BASE / TRANSFORMER CAN SHALL BE WITH UL LISTED BOLTED CONNECTOR OR ONE-HOLE COMPRESSION LUG & 3/8" STAINLESS STEEL BOLTS, NUTS, & WASHERS.
2. FOR EACH REIL UNIT THE CONTRACTOR SHALL TEST THE MADE ELECTRODE GROUND SYSTEM WITH AN INSTRUMENT SPECIFICALLY DESIGNED FOR TESTING GROUND SYSTEMS. TEST RESULTS SHALL BE RECORDED FOR EACH PAPI UNIT INSTALLATION. IF GROUND RESISTANCE EXCEEDS 25 OHMS, CONTACT THE PROJECT ENGINEER FOR FURTHER DIRECTION. COPIES OF THE GROUND SYSTEM TEST RESULTS SHALL BE FURNISHED TO THE RESIDENT ENGINEER/RESIDENT TECHNICIAN, AND THE PROJECT ENGINEER OF RECORD.
3. STEEL USED TO MANUFACTURE GROUND RODS SHALL BE 100 PERCENT DOMESTIC STEEL, TO COMPLY WITH THE STEEL PRODUCTS PROCUREMENT ACT.
4. CLEAN ALL METAL SURFACES BEFORE MAKING GROUND CONNECTIONS. METALLIC SURFACES TO BE JOINED SHALL BE PREPARED BY THE REMOVAL OF ALL NON-CONDUCTIVE MATERIAL PER 2020 NATIONAL ELECTRICAL CODE ARTICLE 250-12.

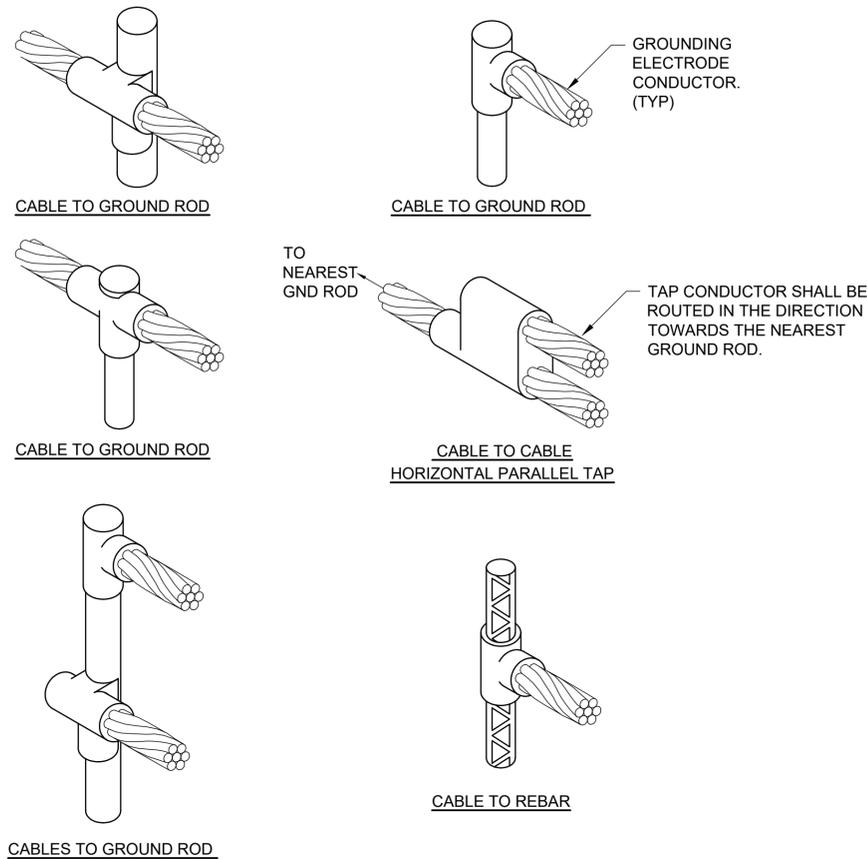

DETAIL NOTES

- KNOWLEDGEABLE AND QUALIFIED PERSONNEL SHALL PERFORM EXOTHERMIC WELD CONNECTIONS TO ENSURE GOOD, SAFE, & RELIABLE CONNECTIONS. ALL BELOW GRADE CONNECTIONS TO GROUND RODS & GROUND RING CONDUCTORS SHALL BE EXOTHERMIC WELD TYPE CONNECTIONS. EXOTHERMIC WELDS SHALL BE CADWELD AS MANUFACTURED BY PENTAIR ERICO PRODUCTS, ULTRAWELD AS MANUFACTURED BY HARGER LIGHTNING PROTECTION & GROUNDING EQUIPMENT, OR THERMOWELD AS MANUFACTURED BY CONTINENTAL INDUSTRIES OR APPROVED EQUAL. VERIFY PROPER SIZES, MOLDS, TYPES, AND REQUIREMENTS FOR THE RESPECTIVE APPLICATION WITH THE MANUFACTURER, AND INSTALL PER THEIR DIRECTIONS.
- INDIVIDUAL GROUNDING ELECTRODE CONDUCTORS SHALL NOT BE INSTALLED IN METAL CONDUIT. INSTALL GROUNDING ELECTRODE CONDUCTORS IN SCHED 80 PVC CONDUIT AS REQUIRED IN FOUNDATIONS, FOR PROTECTION, WHERE ENTERING ENCLOSURES, ETC. WHERE PLASTIC CONDUIT IS USED FOR INDIVIDUAL GROUND WIRES, DO NOT COMPLETELY ENCIRCLE THE CONDUIT WITH FERROUS AND/OR MAGNETIC MATERIALS. WHERE METAL CLAMPS ARE INSTALLED USE NYLON BOLTS, NUTS, WASHERS, & SPACERS TO INTERRUPT A COMPLETE METALLIC PATH FROM ENCIRCLING THE CONDUIT. THIS IS REQUIRED TO AVOID GIRDLING OF GROUND CONDUCTORS. GIRDLING OF A GROUND CONDUCTOR IS THE RESULT OF PLACING THE CONDUCTOR IN A RING OF MAGNETIC MATERIAL. THIS RING COULD BE A METALLIC CONDUIT, U-BOLT OR STRUT SUPPORT PIPE CLAMP, OR OTHER SUPPORT HARDWARE. THE RESULT OF GIRDLING GROUND CONDUCTORS SIGNIFICANTLY INCREASES THE INDUCTIVE IMPEDANCE OF THE GROUND CONDUCTOR. INDUCTIVE AND CAPACITIVE IMPEDANCE IS A TYPE OF RESISTANCE THAT OPPOSES THE FLOW OF ALTERNATING CURRENT. ANY INCREASE IN THE IMPEDANCE OF A GROUND CONDUCTOR REDUCES ITS ABILITY TO EFFECTIVELY MITIGATE RADIO FREQUENCY NOISE IN THE GROUND SYSTEM. THE CONDITION WHERE A GROUND CONDUCTOR IS GIRDLING DURING A LIGHTNING STRIKE RESULTS IN PHENOMENA KNOWN AS SURGE IMPEDANCE LOADING. SURGE IMPEDANCE LOADING IS A RESULT OF VOLTAGE AND CURRENT REACHING 500,000 VOLTS AND 10,000 AMPS FOR A SHORT DURATION. GIRDLING FURTHER INCREASES THE IMPEDANCE AT LIGHTNING FREQUENCIES OF 100 KILOHERTZ TO 100 MEGAHERTZ. AT THESE POWER AND FREQUENCY LEVELS ANY INCREASE IN THE IMPEDANCE OF THE GROUND CONDUCTOR MUST BE CONTROLLED. DURING LIGHTNING DISCHARGE CONDITIONS A LOW INDUCTIVE IMPEDANCE PATH IS MORE IMPORTANT THAN A LOW DC RESISTANCE PATH.
- ALL APPLICATIONS TO GALVANIZED STEEL OR PAINTED STEEL, SHALL REMOVE GALVANIZING AND/OR PAINT & CLEAN THE SURFACE TO EXPOSE BARE STEEL BEFORE MAKING EXOTHERMIC WELD CONNECTION.

EXOTHERMIC WELD DETAILS

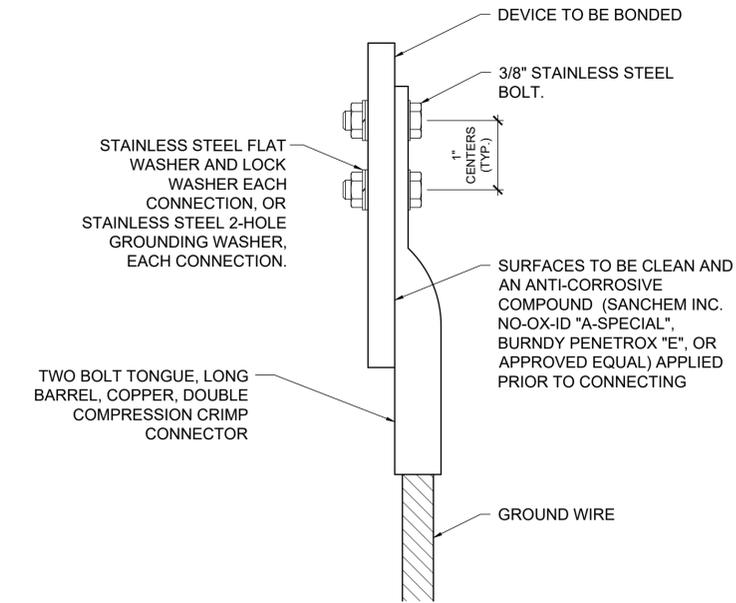


2 HOLE LONG BARREL COMPRESSION LUG TABLE (OR APPROVED EQUAL)

WIRE SIZE	BURNDY CAT. NO.	THOMAS & BETTS CAT. NO.	PENN-UNION CAT. NO.
#8 AWG STRANDED	YA8C-2TC38	256-30695-1157	BBLU-8D-2TC38
#6 AWG SOLID	YA8C-2TC38 OR YGA6C-2TC38E2G1	(CONTACT MFR)	(CONTACT MFR)
#6 AWG STRANDED	YA6C-2TC38	256-30695-1158	BBLU-6D-2TC38
#4 AWG STRANDED	YA4C-2TC38	256-30695-1159	BBLU-4D-2TC38
#2 AWG STRANDED	YA2C-2TC38	256-30695-1160	BBLU-2D-2TC38
#2 AWG SOLID	YA3C-2TC38	256-30695-1160	BBLU-3D-2TC38
#1/0 AWG STRANDED	YA25-2TC38	256-30695-1162	BBLU-1/0D-2TC38
#2/0 AWG STRANDED	YA26-2TC38	256-30695-1116	BBLU-2/0D-2TC38
#3/0 AWG STRANDED	YA27-2TC38	54816BE	BBLU-3/0D-2TC38
#4/0 AWG STRANDED	YA28-2TC38	256-30695-1117	BBLU-4/0D-2TC38

NOTES

- IT IS IMPORTANT TO HAVE GOOD SECURE GROUND CONNECTIONS THAT WILL WITHSTAND WEATHER CONDITIONS AND MAINTAIN CONTINUITY TO GROUND. OFTEN WEATHER CONDITIONS CAN AFFECT GROUNDING CONNECTIONS THAT RESULT IN LOOSE CONNECTIONS AND UNSAFE CONDITIONS.
- SAFETY OF PERSONNEL IS THE PRIORITY. PROTECTION OF EQUIPMENT IS SECONDARY.
- THE GROUND WIRE CONNECTIONS TO EQUIPMENT LOCATED ABOVE GRADE, SHALL BE WITH 2 HOLE TONGUE LONG BARREL COMPRESSION LUGS BOLTED TO THE DEVICE WITH 3/8-INCH STAINLESS STEEL BOLTS, NUTS, AND WASHERS OR WITH THE RESPECTIVE EQUIP MANUFACTURER'S LUG OR TERMINAL WHERE APPLICABLE. THIS ALSO APPLIES TO CONNECTIONS TO GROUND BUS BARS.
- HARGER LIGHTNING PROTECTION AND GROUNDING EQUIPMENT ALSO MANUFACTURERS TWO HOLE LONG BARREL COMPRESSION LUGS.
- EACH CONNECTION SHALL BE COATED WITH A CORROSION PREVENTATIVE COMPOUND (SANCHEM INC. NO-OX-ID "A-SPECIAL", BURNDY PENETROX E, OR APPROVED EQUAL) BEFORE JOINING. ALL COPPER BUS BARS SHALL BE CLEANED PRIOR TO MAKING CONNECTIONS TO REMOVE SURFACE OXIDATION. CLEAN SURFACES, OF RESPECTIVE DEVICES TO BE BONDED, TO BARE METAL, PER NEC 250-12.

GROUNDING LUG CONNECTION DETAIL

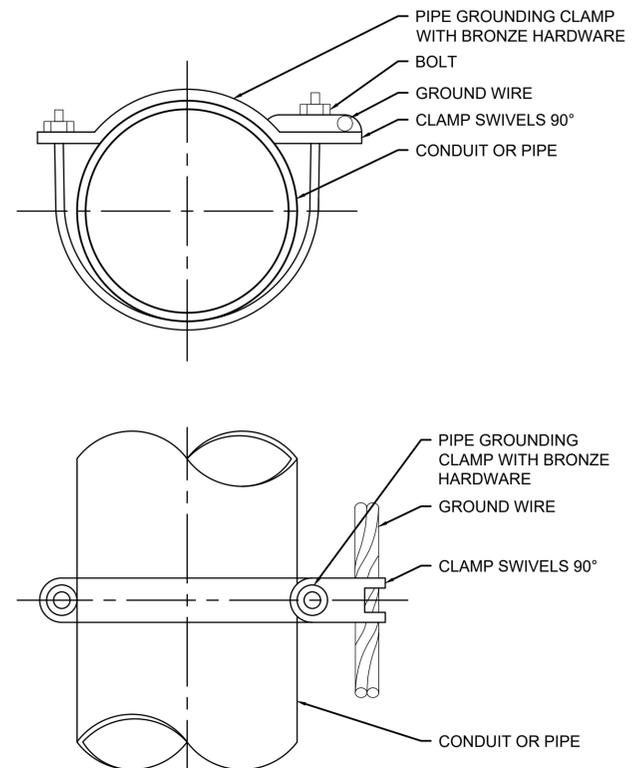

PIPE GROUNDING CLAMP TABLE (OR APPROVED EQUAL)

BURNDY CAT. NO.	THOMAS & BETTS CAT. NO.	PIPE SIZE
GAR3902-BU	3902BU	1/2" - 1"
GAR3903-BU	3903BU	1 1/4" - 2"
GAR3904-BU	3904BU	2 1/2" - 3 1/2"
GAR3905-BU	3905BU	4" - 5"
GAR3906-BU	3906BU	6"

NOTES

- EACH PIPE GROUNDING CLAMP SHALL HAVE BRONZE HARDWARE, BE CORROSION RESISTANT, SUITABLE FOR DIRECT BURIAL IN EARTH OR CONCRETE, & UL 467 LISTED.
- FOR APPLICATIONS SUBJECT TO ADDITIONAL CORROSION, PROVIDE PIPE GROUNDING CLAMPS WITH TINNED COATED BRONZE HARDWARE
- HARGER CPC AND APC SERIES PIPE GROUNDING CLAMPS PROPERLY SIZED FOR THE RESPECTIVE PIPE AND GROUND WIRE ARE ALSO ACCEPTABLE.
- PENN-UNION TYPE "GPL" SERIES PIPE GROUNDING CLAMPS PROPERLY SIZED FOR THE RESPECTIVE PIPE AND GROUND WIRE ARE ALSO ACCEPTABLE.

PIPE/CONDUIT GROUNDING CLAMP DETAIL

INSTALL RUNWAY END IDENTIFIER LIGHTS ON RUNWAY END 13

SBG: 3-17-SBGp-TBD

IDA No: C75-5140


Contract No. MA035

NO.	DATE	DESCRIPTION		
		DES	DWN	REV

ISSUE: AUGUST, 16 2024
PROJECT NO: 23A1045
CAD FILE: E-507-DETL.DWG
DESIGN BY: KNL 05/19/2024
DRAWN BY: JAP 05/02/2024
REVIEWED BY: KNL 6/10/2024

SHEET TITLE

GROUNDING DETAILS

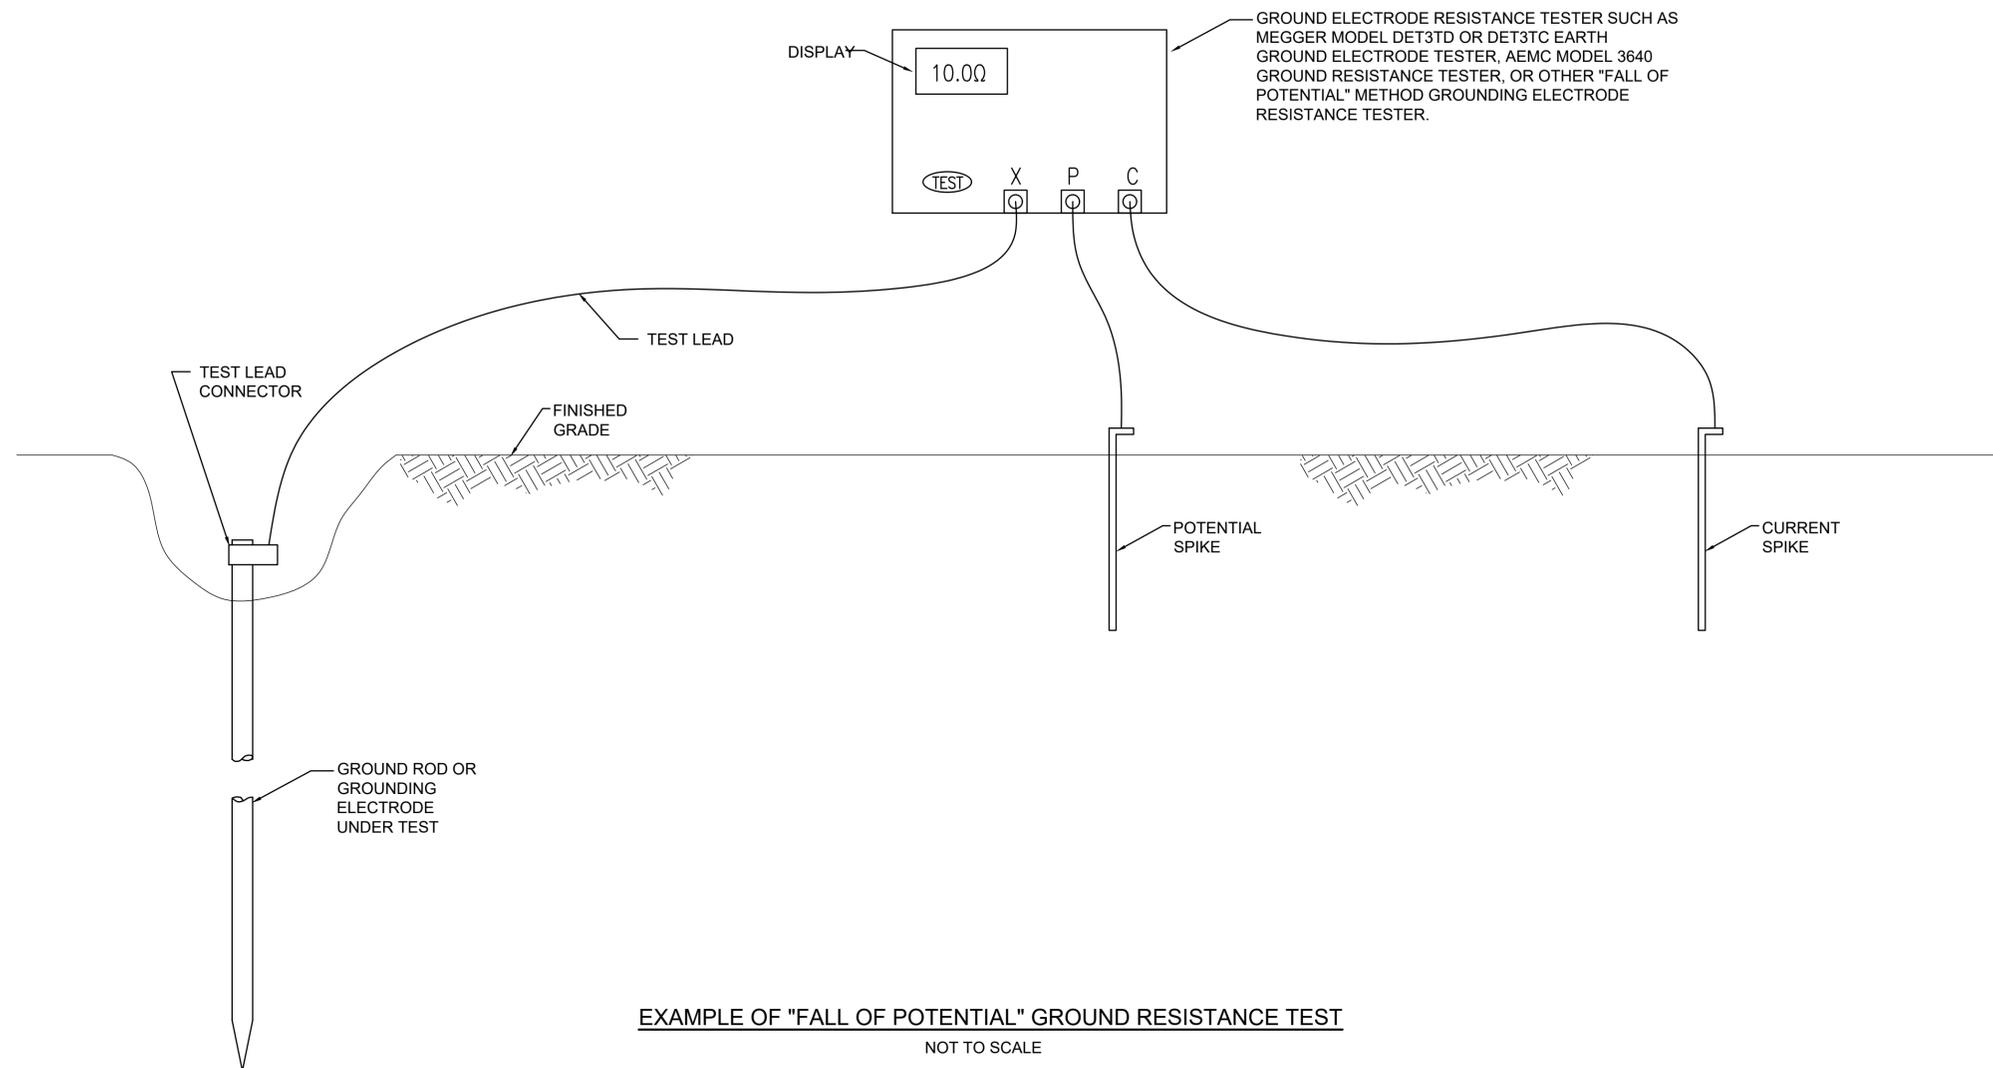

EXAMPLE OF "FALL OF POTENTIAL" GROUND RESISTANCE TEST

NOT TO SCALE

NOTES

1. CONTRACTOR SHALL TEST AND RECORD THE RESISTANCE FOR EACH MADE ELECTRODE GROUND ROD/GROUND FIELD/GROUND RING WITH AN INSTRUMENT SPECIFICALLY DESIGNED FOR TESTING GROUNDING ELECTRODE SYSTEMS. IF GROUND RESISTANCE EXCEEDS 25 OHMS, CONTACT THE PROJECT ENGINEER FOR FURTHER DIRECTION. COPIES OF GROUND ROD TEST RESULTS SHALL BE FURNISHED TO THE RESIDENT ENGINEER/RESIDENT TECHNICIAN, AND THE PROJECT ENGINEER.
2. FOR EACH AIRFIELD LIGHT FIXTURE, TAXI GUIDANCE SIGN, SPLICE CAN AND NAVAID THE CONTRACTOR SHALL TEST THE MADE ELECTRODE GROUND SYSTEM WITH AN INSTRUMENT SPECIFICALLY DESIGNED FOR TESTING GROUND SYSTEMS. TEST RESULTS SHALL BE RECORDED FOR EACH AIRFIELD LIGHT FIXTURE, TAXI GUIDANCE SIGN, AND NAVAIDS INSTALLATION. IF GROUND RESISTANCE EXCEEDS 25 OHMS, CONTACT THE PROJECT ENGINEER FOR FURTHER DIRECTION. ALSO REFER TO EOR-47643 FOR ADDITIONAL INFORMATION ON GROUNDING REQUIREMENTS WHERE APPLICABLE. COPIES OF THE GROUND SYSTEM TEST RESULTS SHALL BE FURNISHED TO THE RESIDENT ENGINEER / RESIDENT TECHNICIAN, AND THE PROJECT ENGINEER OF RECORD.
3. GROUND RESISTANCE TEST SHALL BE CONDUCTED IN ACCORDANCE WITH THE RESPECTIVE GROUND ELECTRODE RESISTANCE TESTING EQUIPMENT MANUFACTURER'S INSTRUCTIONS.
4. RECORD SITE CONDITIONS DURING TESTS.
5. "FALL OF POTENTIAL" TYPE GROUND ELECTRODE RESISTANCE TESTER IS RECOMMENDED FOR TESTING INDIVIDUAL STAND ALONE GROUND RODS.

INSTALL RUNWAY END IDENTIFIER LIGHTS ON RUNWAY END 13

SBG: 3-17-SBGP-TBD

IDA No: C75-5140

Contract No. MA035

NO.	DATE	DESCRIPTION		
		DES	DWN	REV

ISSUE: AUGUST, 16 2024
PROJECT NO: 23A1045
CAD FILE: E-508-DETL.DWG
DESIGN BY: KNL 05/19/2024
DRAWN BY: JAP 05/02/2024
REVIEWED BY: KNL 6/10/2024

SHEET TITLE

GROUND RESISTANCE TESTING DETAILS


GROUNDING NOTES

THE CONTRACTOR SHALL FURNISH AND INSTALL ALL GROUNDING SHOWN ON THE RESPECTIVE CONTRACT DOCUMENTS AND/OR AS MAY BE NECESSARY OR REQUIRED TO MAKE A COMPLETE GROUNDING SYSTEM, AS REQUIRED BY THE LATEST NFPA 70 - NATIONAL ELECTRICAL CODE (NEC) IN FORCE, OTHER APPLICABLE CODES, AND IN ACCORDANCE WITH THE RESPECTIVE EQUIPMENT MANUFACTURER'S RECOMMENDATIONS, INSTRUCTIONS, AND REQUIREMENTS FOR THE PRIORITY OF PROTECTION OF PERSONNEL AND ADDITIONALLY FOR THE PROTECTION OF EQUIPMENT. ALL PERSONNEL ARE RECOMMENDED TO ALSO COMPLY WITH NFPA 70E STANDARD FOR ELECTRICAL SAFETY IN THE WORKPLACE. THE RELIABILITY OF THE GROUNDING SYSTEM IS DEPENDENT ON CAREFUL, PROPER INSTALLATION, AND CHOICE OF MATERIALS. IMPROPER PREPARATION OF SURFACES TO BE JOINED TO MAKE AN ELECTRICAL PATH, LOOSE JOINTS, OR CORROSION CAN INTRODUCE IMPEDANCE THAT WILL SERIOUSLY IMPAIR THE ABILITY OF THE GROUND PATH TO PROTECT PERSONNEL AND EQUIPMENT AND TO ABSORB TRANSIENTS THAT CAN CAUSE NOISE IN COMMUNICATIONS CIRCUITS. THE FOLLOWING FUNCTIONS ARE PARTICULARLY IMPORTANT TO ENSURE A RELIABLE GROUND SYSTEM:

- FURNISH AND INSTALL GROUND RODS AS DETAILED HEREIN. GROUND RODS FOR AIRFIELD LIGHTING LIGHT BASE GROUNDS FOR (RUNWAY LIGHTING, TAXIWAY LIGHTING, & TAXI GUIDANCE SIGNS) SHALL BE MINIMUM 3/4-IN. DIAMETER BY 20-FT LONG, UL-LISTED COPPER CLAD WITH 10-MIL MINIMUM COPPER COATING. GROUND RODS FOR REILS SHALL BE MINIMUM OF TWO 3/4-IN. DIAMETER BY 20-FT. LONG UL-LISTED COPPER CLAD WITH 10-MIL MINIMUM COPPER COATING. GROUND RODS SHALL BE SPACED AS DETAILED ON THE RESPECTIVE PLANS, AND IN NO CASE SPACED LESS THAN ONE ROD LENGTH APART. ALL CONNECTIONS TO GROUND RODS AND THE GROUND RING SHALL BE MADE WITH EXOTHERMIC WELD TYPE CONNECTORS, CADWELD BY PENTAIR ERICO PRODUCTS, THERMOWELD BY CONTINENTAL INDUSTRIES, ULTRAWELD BY HARGER, OR APPROVED EQUAL. EXOTHERMIC WELD CONNECTIONS SHALL BE INSTALLED IN CONFORMANCE WITH THE RESPECTIVE MANUFACTURER'S DIRECTIONS USING MOLDS AS REQUIRED FOR EACH RESPECTIVE APPLICATION. BOLTED CONNECTIONS WILL NOT BE PERMITTED AT GROUND RODS OR AT BURIED GROUNDING ELECTRODE CONDUCTORS.
- CONTRACTOR SHALL TEST EACH MADE ELECTRODE GROUND ROD/GROUND FIELD/GROUND RING WITH AN INSTRUMENT SPECIFICALLY DESIGNED FOR TESTING GROUND FIELD SYSTEMS. IF GROUND RESISTANCE EXCEEDS 25 OHMS, CONTACT THE PROJECT ENGINEER OF RECORD FOR FURTHER DIRECTIONS. COPIES OF GROUND ROD TEST RESULTS SHALL BE FURNISHED TO THE RESIDENT PROJECT REPRESENTATIVE, AND THE PROJECT ENGINEER OF RECORD.
- ALL PRODUCTS ASSOCIATED WITH THE GROUNDING SYSTEM SHALL BE UL-LISTED AND LABELED.
- ALL BOLTED OR MECHANICAL CONNECTIONS SHALL BE COATED WITH A CORROSION PREVENTIVE COMPOUND BEFORE JOINING, SANCHEM INC. "NO-OX-ID "A-SPECIAL" COMPOUND, BURNDY PENETROX E, OR APPROVED EQUAL.
- METALLIC SURFACES TO BE JOINED SHALL BE PREPARED BY THE REMOVAL OF ALL NON-CONDUCTIVE MATERIAL, PER 2020 NATIONAL ELECTRICAL CODE ARTICLE 250-12. ALL COPPER BUS BARS MUST BE CLEANED PRIOR TO MAKING CONNECTIONS TO REMOVE SURFACE OXIDATION.
- METALLIC RACEWAY FITTINGS SHALL BE MADE UP TIGHT TO PROVIDE A PERMANENT LOW IMPEDANCE PATH FOR ALL CIRCUITS. METAL CONDUIT TERMINATIONS IN ENCLOSURES SHALL BE BONDED TO THE ENCLOSURE WITH UL-LISTED FITTINGS SUITABLE FOR GROUNDING. PROVIDE GROUNDING BUSHINGS WITH BONDING JUMPERS FOR ALL METAL CONDUITS ENTERING SERVICE EQUIPMENT (METER BASE, CT CABINET, MAIN SERVICE BREAKER ENCLOSURE, ETC.). PROVIDE GROUNDING BUSHINGS WITH BONDING JUMPERS FOR ALL METAL CONDUITS ENTERING AN ENCLOSURE THROUGH CONCENTRIC OR ECCENTRIC KNOCKOUTS THAT ARE PUNCHED OR OTHERWISE FORMED SO AS TO IMPAIR THE ELECTRICAL CONNECTION TO GROUND. STANDARD LOCKNUTS OR BUSHINGS SHALL NOT BE THE SOLE MEANS FOR BONDING WHERE A CONDUIT ENTERS AN ENCLOSURE THROUGH A CONCENTRIC OR ECCENTRIC KNOCKOUT
- ALL CONNECTIONS, LOCATED ABOVE GRADE, BETWEEN THE DIFFERENT TYPES OF GROUNDING CONDUCTORS SHALL BE MADE USING UL-LISTED DOUBLE COMPRESSION CRIMP TYPE CONNECTORS OR UL-LISTED BOLTED GROUND CONNECTORS. FOR GROUND CONNECTIONS TO ENCLOSURES, CASES AND FRAMES OF ELECTRICAL EQUIPMENT NOT SUPPLIED WITH GROUND LUGS THE CONTRACTOR SHALL DRILL REQUIRED HOLES FOR MOUNTING A BOLTED GROUND CONNECTOR. ALL BOLTED GROUND CONNECTORS SHALL BE BURNDY, THOMAS AND BETTS, OR EQUAL. TIGHTEN CONNECTIONS TO COMPLY WITH TIGHTENING TORQUES IN UL STANDARD 486A TO ASSURE PERMANENT AND EFFECTIVE GROUNDING.
- ALL METAL EQUIPMENT ENCLOSURES, CONDUITS, CABINETS, BOXES, RECEPTACLES, MOTORS, ETC. SHALL BE BONDED TO THE RESPECTIVE GROUNDING SYSTEM.
- PROVIDE ALL BOXES FOR PROPOSED OUTLETS, SWITCHES, CIRCUIT BREAKERS, ETC. WITH GROUNDING SCREWS. PROVIDE ALL PANELBOARD, SWITCHGEAR, ETC., ENCLOSURES WITH GROUNDING BARS WITH INDIVIDUAL SCREWS, LUGS, CLAMPS, ETC., FOR EACH OF THE GROUNDING CONDUCTORS THAT ENTER THEIR RESPECTIVE ENCLOSURES.
- EACH NEW FEEDER CIRCUIT AND/OR BRANCH CIRCUIT SHALL INCLUDE AN EQUIPMENT GROUND WIRE. METAL RACEWAY OR CONDUIT SHALL NOT MEET THIS REQUIREMENT. THE EQUIPMENT GROUND WIRE FROM EQUIPMENT SHALL NOT BE SMALLER THAN ALLOWED BY 2020 NEC TABLE 250-122 "MINIMUM SIZE CONDUCTORS OR GROUNDING RACEWAY AND EQUIPMENT." WHEN CONDUCTORS ARE ADJUSTED IN SIZE TO COMPENSATE FOR VOLTAGE DROP, EQUIPMENT-GROUNDING CONDUCTORS SHALL BE ADJUSTED PROPORTIONATELY ACCORDING TO CIRCULAR MIL AREA. ALL EQUIPMENT GROUND WIRES SHALL BE COPPER, EITHER BARE OR INSULATED GREEN IN COLOR. WHERE THE EQUIPMENT GROUNDING CONDUCTORS ARE INSULATED, THEY SHALL BE IDENTIFIED BY THE COLOR GREEN, AND SHALL BE THE SAME INSULATION TYPE AS THE PHASE CONDUCTORS.

- ALL EXTERIOR METAL CONDUIT, WHERE NOT ELECTRICALLY CONTINUOUS BECAUSE OF MANHOLES, HANDHOLES, NON-METALLIC JUNCTION BOXES, ETC., SHALL BE BONDED TO ALL OTHER METAL CONDUIT IN THE RESPECTIVE DUCT RUN, AND AT EACH END, WITH A COPPER-BONDING JUMPER SIZED IN CONFORMANCE WITH 2020 NEC 250-102. WHERE METAL CONDUITS TERMINATE IN AN ENCLOSURE (SUCH AS A MOTOR CONTROL CENTER, SWITCHBOARD, ETC) WHERE THERE IS NOT ELECTRICAL CONTINUITY WITH THE CONDUIT AND THE RESPECTIVE ENCLOSURE, PROVIDE A BONDING JUMPER FROM THE RESPECTIVE ENCLOSURE GROUND BUS TO THE CONDUIT SIZED PER 2020 NEC 250-102.
- IT IS THE INTENT OF THIS SPECIFICATION THAT ALL MOTOR FRAMES, PUMP BASES ELECTRICAL EQUIPMENT ENCLOSURES, PANEL HOUSINGS, CONDUITS, BOXES, ETC. HAVE A CONTINUOUS COPPER WIRE GROUND CONNECTION AND SHALL BE POSITIVELY BONDED TO THE RESPECTIVE GROUNDING SYSTEM. CONDUIT CONNECTORS WILL NOT BE CONSIDERED AS ADEQUATE GROUNDING.
- PROVIDE A POSITIVE GROUND BOND FOR ALL OUTLET BOXES, ELECTRICAL EQUIPMENT ENCLOSURES, GROUNDING RECEPTACLES, TOGGLE SWITCHES, ETC. INSTALL A GROUNDING CONDUCTOR IN ALL WIRE AND CABLE RACEWAYS. GROUND CONDUCTOR TO HAVE 600-VOLT INSULATION AND BE IDENTIFIED BY A CONTINUOUS GREEN COLOR COATING. THEY SHALL BE USED SOLELY FOR GROUNDING PURPOSES AND BE ENTIRELY SEPARATE FROM WHITE GROUNDED NEUTRAL CONDUCTOR, EXCEPT AT SUPPLY SIDE OF SERVICE DISCONNECTING MEANS, WHERE GROUNDING AND NEUTRAL SYSTEMS ARE TO BE CONNECTED TO SERVICE GROUND.
- EACH AND ALL GROUNDED CASED AND METAL PARTS ASSOCIATED WITH ELECTRICAL EQUIPMENT SHALL BE TESTED FOR CONTINUITY OF CONNECTION WITH GROUND BUS SYSTEM BY CONTRACTOR IN PRESENCE OF OWNER'S REPRESENTATIVE.
- ALL CONNECTIONS BETWEEN THE DIFFERENT TYPES OF GROUNDING CONDUCTORS ABOVE GRADE SHALL BE MADE USING BOLTED GROUND CONNECTORS. GROUND LUGS SHALL BE PROVIDED IN ALL ENCLOSURES AND WIRING TERMINATION JUNCTION BOXES. EQUIPMENT GROUNDS AND GROUNDING CONDUCTOR SHALL BE CONNECTED TO THESE GROUND LUGS. FOR GROUND CONNECTIONS TO ENCLOSURES, CASES AND FRAMES OF ELECTRICAL EQUIPMENT NOT SUPPLIED WITH GROUND LUGS THE CONTRACTOR SHALL DRILL REQUIRED HOLES FOR MOUNTING A BOLTED GROUND CONNECTOR. ALL BOLTED GROUND CONNECTORS SHALL BE BURNDY, OR EQUAL.
- BOND ALL NONCURRENT-CARRYING PARTS OF METAL EQUIPMENT TO GROUND SYSTEM.
- BUILDING STRUCTURAL STEEL SYSTEM SHALL BE BONDED TO ELECTRICAL GROUND SYSTEM.
- INSTALL GROUNDING ELECTRODE CONDUCTORS, LIGHTNING PROTECTION DOWN CONDUCTORS AND SEPARATE GROUND CONDUCTORS IN SCHEDULE 80 PVC CONDUIT OR EXPOSED WHERE ACCEPTABLE TO LOCAL CODES. WHERE GROUNDING ELECTRODE CONDUCTORS, LIGHTNING PROTECTION DOWN CONDUCTORS OR INDIVIDUAL GROUND CONDUCTORS ARE RUN IN PVC CONDUIT, DO NOT COMPLETELY ENCIRCLE CONDUIT WITH FERROUS AND/OR MAGNETIC MATERIALS. USE NON-METALLIC REINFORCED FIBERGLASS STRUT SUPPORT. WHERE METAL CONDUIT CLAMPS ARE INSTALLED, USE NYLON BOLTS, NUTS, WASHERS AND SPACERS TO INTERRUPT A COMPLETE METALLIC PATH FROM ENCIRCLING THE CONDUIT. THIS IS REQUIRED TO AVOID GIRDLING OF GROUND CONDUCTORS.
- IF LOCAL CODES DICTATE THAT INDIVIDUAL GROUNDING CONDUCTORS MUST BE RUN IN METAL CONDUIT OR RACEWAY, THEN THE CONDUIT OR RACEWAY MUST BE BONDED AT EACH END OF THE RUN WITH A BONDING JUMPER SIZED EQUAL TO THE INDIVIDUAL GROUNDING CONDUCTOR OR AS REQUIRED BY 2020 NEC 250-102 AND/OR 2020 NEC 250.64(E). NOTE THIS DOES NOT APPLY TO AC EQUIPMENT GROUNDING CONDUCTORS RUN WITH AC CIRCUITS. CONFIRM REQUIREMENTS WITH AUTHORITY HAVING JURISDICTION.
- GROUNDING WORK AFFECTING OPERATIONS AT A FACILITY SHALL BE COORDINATED WITH THE OWNER'S DESIGNATED REPRESENTATIVE(S) AND TO MINIMIZE DOWNTIME TO EXISTING SYSTEMS. THE RESPECTIVE PERSONNEL SHALL COORDINATE WORK AND ANY POWER OUTAGES WITH THE OWNER'S DESIGNATED REPRESENTATIVE(S). ANY SHUTDOWN OF EXISTING SYSTEMS SHALL BE SCHEDULED WITH AND APPROVED BY THE OWNER'S REPRESENTATIVE PRIOR TO SHUT DOWN. ALL POWER SYSTEMS (AC OR DC) SHALL HAVE PROVISIONS TO LOCKOUT AND TAGOUT ANY CIRCUIT TO HELP ENSURE THE CIRCUIT IS SAFE TO WORK ON FOR PROTECTION OF PERSONNEL. ONCE SHUT DOWN, THE CIRCUITS SHALL BE LABELED AS SUCH TO PREVENT ACCIDENTAL ENERGIZING OF THE RESPECTIVE CIRCUITS. ALL PERSONNEL SHALL FOLLOW U.S. DEPARTMENT OF LABOR OCCUPATIONAL SAFETY & HEALTH ADMINISTRATION (OSHA) 29 CFR PART 1910 OCCUPATIONAL SAFETY AND HEALTH STANDARDS FOR ELECTRICAL SAFETY AND LOCKOUT/TAGOUT PROCEDURES INCLUDING, BUT NOT LIMITED TO, 29 CFR SECTION 1910.147 THE CONTROL OF HAZARDOUS ENERGY (LOCKOUT/TAGOUT), WHERE A FACILITY DOES NOT HAVE LOCKOUT/TAGOUT KITS THE RESPECTIVE PERSONNEL SHALL PROVIDE ADEQUATE QUANTITIES OF LOCKOUT/TAGOUT KITS SUITABLE FOR USE WITH THE RESPECTIVE EQUIPMENT. WHERE EXISTING ELECTRICAL EQUIPMENT DOES NOT HAVE FEATURES FOR LOCKOUT/TAGOUT THE RESPECTIVE PERSONNEL WILL BE RESPONSIBLE FOR PROVIDING THE APPROPRIATE LOCKOUT/TAGOUT EQUIPMENT AND MEASURES TO COMPLY WITH OSHA LOCKOUT/TAGOUT REQUIREMENTS. ALL PADLOCKS FOR USE WITH LOCKOUT/TAGOUT PROCEDURES SHALL HAVE A DIFFERENT KEY. PROVIDE LOCKOUT HASPS TO ACCOMMODATE MULTIPLE PADLOCKS WHERE MULTIPLE PEOPLE ARE WORKING ON THE SAME SYSTEM. INCLUDE LOCKOUT TAGS FOR EACH PIECE OF EQUIPMENT REQUIRING SERVICING AND SHUTDOWN. COMPLIANCE WITH LOCKOUT/TAGOUT PROCEDURES AND ALL OTHER SAFETY PROCEDURES AND REQUIREMENTS ARE THE RESPONSIBILITY OF THE RESPECTIVE PERSONNEL WORKING AT THE FACILITY.

- NEVER REMOVE, ALTER, OR ATTEMPT TO REPAIR CONDUCTORS OR CONDUIT SYSTEMS PROVIDING GROUNDING OR ELECTRICAL BONDING FOR ANY ELECTRICAL EQUIPMENT UNTIL ALL POWER IS REMOVED FROM EQUIPMENT. WARN ALL PERSONNEL OF THE UNGROUNDED CONDITION OF THE EQUIPMENT. DISPLAY APPROPRIATE WARNING SIGNS, SUCH AS DANGER TAGS, TO WARN PERSONNEL OF THE POSSIBLE HAZARDS.
- GROUNDING WORK AND MODIFICATIONS SHALL NOT BE PERFORMED DURING A THUNDERSTORM OR WHEN A THUNDERSTORM IS PREDICTED IN THE AREA.
- PER NFPA 70E STANDARD FOR ELECTRICAL SAFETY IN THE WORKPLACE IT DEFINES ELECTRICALLY SAFE WORK CONDITION AS "A STATE IN WHICH AN ELECTRICAL CONDUCTOR OR CIRCUIT PART HAS BEEN DISCONNECTED FROM ENERGIZED PARTS, LOCKED/TAGGED IN ACCORDANCE WITH ESTABLISHED STANDARDS, TESTED TO VERIFY THE ABSENCE OF VOLTAGE, AND, IF NECESSARY, TEMPORARILY GROUNDED FOR PERSONNEL PROTECTION." PRIOR TO CONDUCTING TESTS OR WORKING ON EQUIPMENT, VERIFY EQUIPMENT ENCLOSURES AND FRAMES HAVE A GOOD AND SECURE GROUND CONNECTION. FAILURE TO PROPERLY GROUND THIS EQUIPMENT PRESENTS A DANGEROUS HAZARD FOR PERSONNEL WORKING ON THIS SYSTEM.
- WHERE A CONFLICT IS DETERMINED WITH RESPECT TO GROUNDING REQUIREMENTS PER MANUFACTURER INSTALLATION INSTRUCTIONS, NEC, AND/OR THE CONTRACT DOCUMENTS, CONTACT THE PROJECT ENGINEER OF RECORD; KEVIN LIGHTFOOT FOR FURTHER DIRECTIONS.
- GROUND RODS SHALL BE PRODUCED FROM 100 PERCENT DOMESTIC STEEL TO COMPLY WITH THE AIRPORT IMPROVEMENT PROGRAM BUY AMERICAN PREFERENCES REQUIREMENT. THE BUY AMERICAN PREFERENCE REQUIREMENTS ESTABLISHED WITHIN 49 USC §0101 REQUIRE THAT ALL STEEL AND MANUFACTURED GOODS USED ON AIP PROJECTS MUST BE PRODUCED IN THE UNITED STATES.

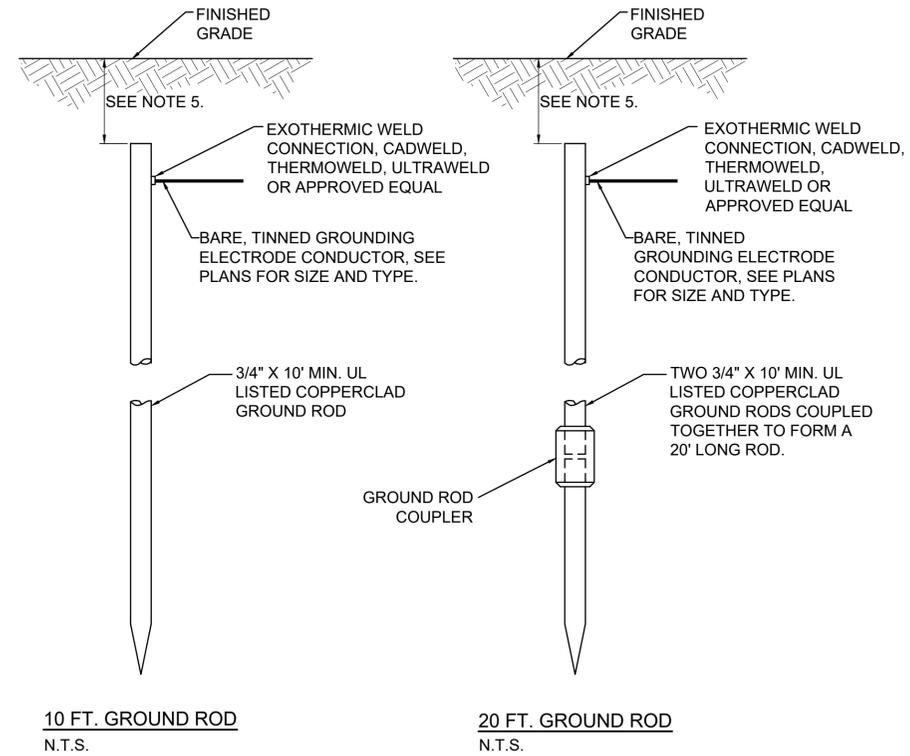

GROUND RODS
N.T.S.

NOTES

- TYPE AND MINIMUM NUMBER OF GROUND RODS SHALL BE AS SPECIFIED ON THE PLAN.
- THE RESISTANCE TO GROUND OF THE GROUNDING SYSTEM SHALL NOT EXCEED 25 OHMS.
- COST OF GROUND RODS IS INCIDENTAL TO THE ASSOCIATED ITEMS REQUIRING GROUNDING UNLESS OTHERWISE SPECIFIED.
- GROUND RODS SHALL BE SPACED AS DETAILED ON THE PLANS AND SHALL NOT BE SPACED LESS THAN ONE ROD LENGTH APART.
- TOP OF GROUND RODS SHALL BE 12" MINIMUM BELOW GRADE UNLESS DETAILED OTHERWISE HEREIN.
- GROUND RODS FOR REILS SHALL BE A MINIMUM OF TWO 3/4-INCH DIAMETER BY 20-FT LONG UL LISTED COPPER CLAD RODS SPACED 20 FEET APART.
- FOR OTHER GROUNDING APPLICATIONS NOT DETAILED HEREIN, CONTACT ENGINEER OF RECORD; KEVIN LIGHTFOOT FOR DIRECTIONS.



Offices Nationwide
www.hanson-inc.com

Hanson Professional Services Inc.
1525 S. 6th Street
Springfield, IL 62703
phone: 217-788-2450
fax: 217-788-2503

Illinois Licensed
Professional Service Corporation
#184-001084



Marshall County Airport
1315 Illinois 17
Lacon, Illinois 61540
phone: 309-246-2870

INSTALL RUNWAY END IDENTIFIER LIGHTS ON RUNWAY END 13

SBG: 3-17-SBG-TPD

IDA No: C75-5140

Contract No. MA035

NO.	DATE	DESCRIPTION		
		DES	DWN	REV

ISSUE: AUGUST, 16 2024
PROJECT NO: 23A1045
CAD FILE: E-003-NOTES.DWG
DESIGN BY: KNL 05/19/2024
DRAWN BY: JAP 05/02/2024
REVIEWED BY: KNL 6/10/2024

SHEET TITLE

GROUNDING NOTES



ELECTRICAL LEGEND - ONE-LINE DIAGRAM	
	CABLE TERMINATOR/LUG
	TRANSFORMER
	DISCONNECT SWITCH
	FUSIBLE DISCONNECT SWITCH
	CIRCUIT BREAKER
	THERMAL MAGNETIC CIRCUIT BREAKER
	FUSE
	TRANSIENT VOLTAGE SURGE SUPPRESSOR OR SURGE PROTECTOR DEVICE
	GROUND - GROUND ROD, GROUNDING ELECTRODE, OR AT EARTH POTENTIAL
	INDICATING LIGHT
	MOTOR
	LOAD, MOTOR, # = HORSEPOWER
	ELECTRIC UTILITY METER BASE
	JUNCTION BOX WITH SPLICE
	EQUIPMENT, XXX = DEVICE DESCRIPTION
	GROUND BUS OR TERMINAL
	NEUTRAL BUS
	PANELBOARD WITH MAIN LUGS
	PANELBOARD WITH MAIN BREAKER
	FUSE PANEL WITH MAIN FUSE PULLOUT
	DUPLEX RECEPTACLE 120V SINGLE PHASE GROUNDING TYPE
	CONTROL STATION
	TRANSFER SWITCH
	ENGINE GENERATOR SET

ELECTRICAL LEGEND - SCHEMATIC	
	NORMALLY OPEN (N.O.) CONTACT
	NORMALLY CLOSED (N.C.) CONTACT
	STARTER COIL, * = STARTER NUMBER
	OVERLOAD RELAY CONTACT
	CONTROL RELAY, * = CONTROL RELAY NUMBER
	RELAY, * = RELAY NUMBER
	TOGGLE SWITCH / 2 POSITION SWITCH
	2-POSITION SELECTOR SWITCH
	3-POSITION SELECTOR SWITCH (H-O-A SHOWN)
	N.O. THERMAL SWITCH
	N.C. THERMAL SWITCH
	2 POLE DISCONNECT SWITCH
	3 POLE DISCONNECT SWITCH
	PHOTOCELL
	TERMINAL BLOCK, * = TERMINAL NUMBER
	DEVICE TERMINAL, * = DEVICE TERMINAL NUMBER
	INTERNAL PANEL WIRING
	FIELD WIRING
	FUSE
	GROUND BUS OR TERMINAL
	NEUTRAL BUS
	GROUND, GROUND ROD, GROUND BUS
	INDUSTRIAL CONTROL RELAY OR LIGHTING CONTACTOR
	TYPE S1 CUTOUT HANDLE REMOVED (MFRD BY CROUSE-HINDS, MANAIRCO, AND OTHERS)
	TYPE S1 CUTOUT HANDLE INSERTED (MFRD BY CROUSE-HINDS, MANAIRCO, AND OTHERS)
	TYPE SCO CUTOUT (MFRD BY ADB)
	TYPE ALS AIRFIELD LIGHTING SAFETY CUTOUT (MFRD BY ADB)
	L-830 SERIES ISOLATION TRANSFORMER

ELECTRICAL ABBREVIATIONS	
A.F.F.	ABOVE FINISHED FLOOR
A, AMP	AMPERES
ATS	AUTOMATIC TRANSFER SWITCH
AWG	AMERICAN WIRE GAUGE
BKR	BREAKER
C	CONDUIT
CB	CIRCUIT BREAKER
CKT	CIRCUIT
CR	CONTROL RELAY
CU	COPPER
DPDT	DOUBLE POLE DOUBLE THROW
DPST	DOUBLE POLE SINGLE THROW
EM	EMERGENCY
EMT	ELECTRICAL METALLIC TUBING
ENCL	ENCLOSURE
EOR	ENGINEER OF RECORD
EP	EXPLOSION PROOF
ES	EMERGENCY STOP
ETL	INTERTEK - ELECTRICAL TESTING LABS
ETM	ELAPSE TIME METER
GFCI	GROUND FAULT CIRCUIT INTERRUPTER
GFI	GROUND FAULT INTERRUPTER
GND	GROUND
GRSC	GALVANIZED RIGID STEEL CONDUIT
HID	HIGH INTENSITY DISCHARGE
HOA	HAND OFF AUTOMATIC
HP	HORSEPOWER
HPS	HIGH PRESSURE SODIUM
J	JUNCTION BOX
KVA	KILOVOLT AMPERE(S)
KNL	KEVIN NEIL LIGHTFOOT
KW	KILOWATTS
LC	LIGHTING CONTACTOR
LTFMC	LIQUID TIGHT FLEXIBLE METAL CONDUIT (UL LISTED)
LTG	LIGHTING
LP	LIGHTING PANEL
MAX	MAXIMUM
MCB	MAIN CIRCUIT BREAKER
MCM	THOUSAND CIRCULAR MIL
MDP	MAIN DISTRIBUTION PANEL
MFR	MANUFACTURER
MH	METAL HALIDE
MIN	MINIMUM
MLO	MAIN LUGS ONLY
NEC	NATIONAL ELECTRICAL CODE (NFPA 70)
NC	NORMALLY CLOSED
NO	NORMALLY OPEN
NTS	NOT TO SCALE
OHE	OVERHEAD ELECTRIC
OL	OVERLOAD

ELECTRICAL ABBREVIATIONS (CONTINUED)	
PB	PULL BOX
PC	PHOTO CELL
PDB	POWER DISTRIBUTION BLOCK
PNL	PANEL
RCPT	RECEPTACLE
R	RELAY
S	STARTER
SPD	SURGE PROTECTION DEVICE
SPST	SINGLE POLE SINGLE THROW
TVSS	TRANSIENT VOLTAGE SURGE SUPPRESSOR
TYP	TYPICAL
UG	UNDERGROUND
UGE	UNDERGROUND ELECTRIC
UL	UNDERWRITER'S LABORATORIES
V	VOLTS
W/	WITH
W/O	WITHOUT
WP	WEATHER PROOF
XFER	TRANSFER
XFMR	TRANSFORMER

AIRPORT EQUIPMENT/FACILITY ABBREVIATIONS	
ASOS	AUTOMATED SURFACE OBSERVING SYSTEM
ATCT	AIR TRAFFIC CONTROL TOWER
AWOS	AUTOMATED WEATHER OBSERVING SYSTEM
CCR	CONSTANT CURRENT REGULATOR
DME	DISTANCE MEASURING EQUIPMENT
FAR	FEDERAL AVIATION REGULATION
GS	GLIDE SLOPE FACILITY
HIRL	HIGH INTENSITY RUNWAY LIGHT
ILS	INSTRUMENT LANDING SYSTEM
IM	INNER MARKER
LIR	LOW IMPACT-RESISTANT
LOC	LOCALIZER FACILITY
MALS	MEDIUM INTENSITY APPROACH LIGHTING SYSTEM
MALSR	MEDIUM INTENSITY APPROACH LIGHTING SYSTEM WITH RUNWAY ALIGNMENT INDICATING LIGHTS
MIRL	MEDIUM INTENSITY RUNWAY LIGHT
MITL	MEDIUM INTENSITY TAXIWAY LIGHT
NDB	NON-DIRECTIONAL BEACON
PAPI	PRECISION APPROACH PATH INDICATOR
PLASI	PULSE LIGHT APPROACH SLOPE INDICATOR
RAIL	RUNWAY ALIGNMENT INDICATING LIGHTS
REIL	RUNWAY END IDENTIFIER LIGHT
RVR	RUNWAY VISUAL RANGE
VADI	VISUAL APPROACH DESCENT INDICATOR
VASI	VISUAL APPROACH SLOPE INDICATOR
VOR	VERY HIGH FREQUENCY OMNIDIRECTIONAL RANGE FACILITY
WC	WIND CONE

NOTES:

- ALL ELECTRICAL EQUIPMENT SHALL BE INSTALLED IN CONFORMANCE WITH NFPA 70 - NATIONAL ELECTRICAL CODE (NEC) MOST CURRENT ISSUE IN FORCE, THE RESPECTIVE EQUIPMENT MANUFACTURER'S DIRECTIONS AND ALL OTHER APPLICABLE LOCAL CODES, LAWS, ORDINANCES, AND REQUIREMENTS IN FORCE. ANY INSTALLATIONS WHICH VOID THE U.L. LISTING, INTERTEK TESTING SERVICES VERIFICATION/ETL LISTING (OR OTHER THIRD PARTY LISTING) AND/OR THE MANUFACTURER'S WARRANTY OF A DEVICE WILL NOT BE PERMITTED.
- KEEP A COPY OF THE LATEST NEC IN FORCE ON SITE AT ALL TIMES DURING/CONSTRUCTION FOR USE AS A REFERENCE.
- NEW WORK, POWER OUTAGES, AND/OR SHUT DOWN OF EXISTING SYSTEMS SHALL BE COORDINATED WITH THE AIRPORT MANAGER. ONCE SHUT DOWN, THE CIRCUITS SHALL BE LABELED AS SUCH TO PREVENT ACCIDENTAL ENERGIZING OF THE RESPECTIVE CIRCUITS. ALL PERSONNEL SHALL FOLLOW U.S. DEPARTMENT OF LABOR OCCUPATIONAL SAFETY & HEALTH ADMINISTRATION (OSHA) 29 CFR PART 1910 OCCUPATIONAL SAFETY & HEALTH STANDARDS FOR ELECTRICAL SAFETY AND LOCKOUT/TAGOUT PROCEDURES INCLUDING, BUT NOT LIMITED TO, 29 CFR SECTION 1910.147 THE CONTROL OF HAZARDOUS ENERGY (LOCKOUT/TAGOUT).
- LTFMC DENOTES LIQUID TIGHT FLEXIBLE METAL CONDUIT UL LISTED, SUNLIGHT RESISTANT, & SUITABLE FOR GROUNDING. LIQUID TIGHT FLEXIBLE METAL CONDUIT AND ASSOCIATED FITTINGS SHALL BE U.L. LISTED TO MEET THE REQUIREMENTS OF NEC 350.6. LIQUID TIGHT FLEXIBLE METAL CONDUIT THAT IS USED FOR FLEXIBILITY (INCLUDING CONNECTIONS TO CCR'S & TRANSFORMERS) SHALL REQUIRE AN EXTERNAL BONDING JUMPER OR INTERNAL EQUIPMENT GROUNDING CONDUCTOR PER NEC 350.60. EXTERNAL BONDING JUMPERS USED WITH CCR INSTALLATIONS SHALL BE #6 AWG COPPER (MINIMUM). DO NOT INSTALL LTFMC THAT IS NOT UL LISTED. CONFIRM LTFMC BEARS THE UL LABEL PRIOR TO INSTALLATION.
- INSULATED CONDUCTORS SHALL COLOR CODE PHASE AND NEUTRAL CONDUCTOR INSULATION FOR NO. 6 AWG OR SMALLER. PROVIDE COLORED INSULATION OR COLORED MARKING TAPE FOR PHASE AND NEUTRAL CONDUCTORS FOR NO. 4 AWG AND LARGER. INSULATED GROUND CONDUCTORS SHALL HAVE GREEN COLORED INSULATION FOR ALL CONDUCTOR AWG AND/OR KCMIL TO COMPLY WITH NEC 250.119. NEUTRAL CONDUCTORS SHALL HAVE WHITE COLORED INSULATION FOR NO. 6 AWG AND SMALLER TO MEET THE REQUIREMENTS OF NEC 200.6. STANDARD COLORS FOR POWER WIRING AND BRANCH CIRCUITS SHALL BE AS FOLLOWS:

<u>120/240 VAC, 1 PHASE, 3 WIRE</u>	
PHASE A	BLACK
PHASE C	BLUE
NEUTRAL	WHITE
GROUND	GREEN
- SEE RESPECTIVE SITE PLANS FOR SITE LEGEND INFORMATION.
- ENCLOSURES RATED NEMA 4, 4X SHALL HAVE WATERTIGHT HUBS AT CONDUIT ENTRANCES UL LISTED NEMA 4, 4X FOR THE RESPECTIVE ENCLOSURE, TO MAINTAIN THE NEMA 4, 4X RATING.
- ONLY QUALIFIED ELECTRICAL CONTRACTORS SHALL PERFORM ELECTRICAL WORK ON THIS PROJECT. NEC DEFINES A QUALIFIED PERSON AS "ONE WHO HAS SKILLS AND KNOWLEDGE RELATED TO THE CONSTRUCTION AND OPERATION OF THE ELECTRICAL EQUIPMENT AND INSTALLATIONS AND HAS RECEIVED SAFETY TRAINING TO RECOGNIZE AND AVOID THE HAZARDS INVOLVED."
- RESPECTIVE POWER SOURCES FOR EACH PANEL, EQUIPMENT, AIRFIELD LIGHT, SIGN, NAVIAD, OR OTHER DEVICE SHALL BE VERIFIED PRIOR TO WORKING ON, RELOCATING, REMOVING, DISCONNECTING, AND/OR INSTALLING THE RESPECTIVE DEVICES. SHUT OFF, LOCKOUT, AND TAGOUT FOR PROTECTION OF PERSONNEL.
- HIGH VOLTAGE CIRCUITS (AIRFIELD LIGHTING 5000 VOLT SERIES CIRCUITS AND OTHER CIRCUITS RATED ABOVE 600 VOLTS) AND LOW VOLTAGE CIRCUITS (RATED 600 VOLTS AND BELOW) SHALL NOT BE INSTALLED IN THE SAME WIREWAY, CONDUIT, DUCT, RACEWAY, JUNCTION STRUCTURE OR HANDHOLE.

INSTALL RUNWAY END IDENTIFIER LIGHTS ON RUNWAY END 13

SBG: 3-17-SBG-P-TBD

IDA No: C75-5140


Contract No. MA035

NO.	DATE	DESCRIPTION		
		DES	DWN	REV

ISSUE: AUGUST, 16 2024
PROJECT NO: 23A1045
CAD FILE: E-004-LGND.DWG
DESIGN BY: KNL 05/19/2024
DRAWN BY: JAP 05/02/2024
REVIEWED BY: KNL 6/10/2024

SHEET TITLE

ELECTRICAL LEGEND AND ABBREVIATIONS

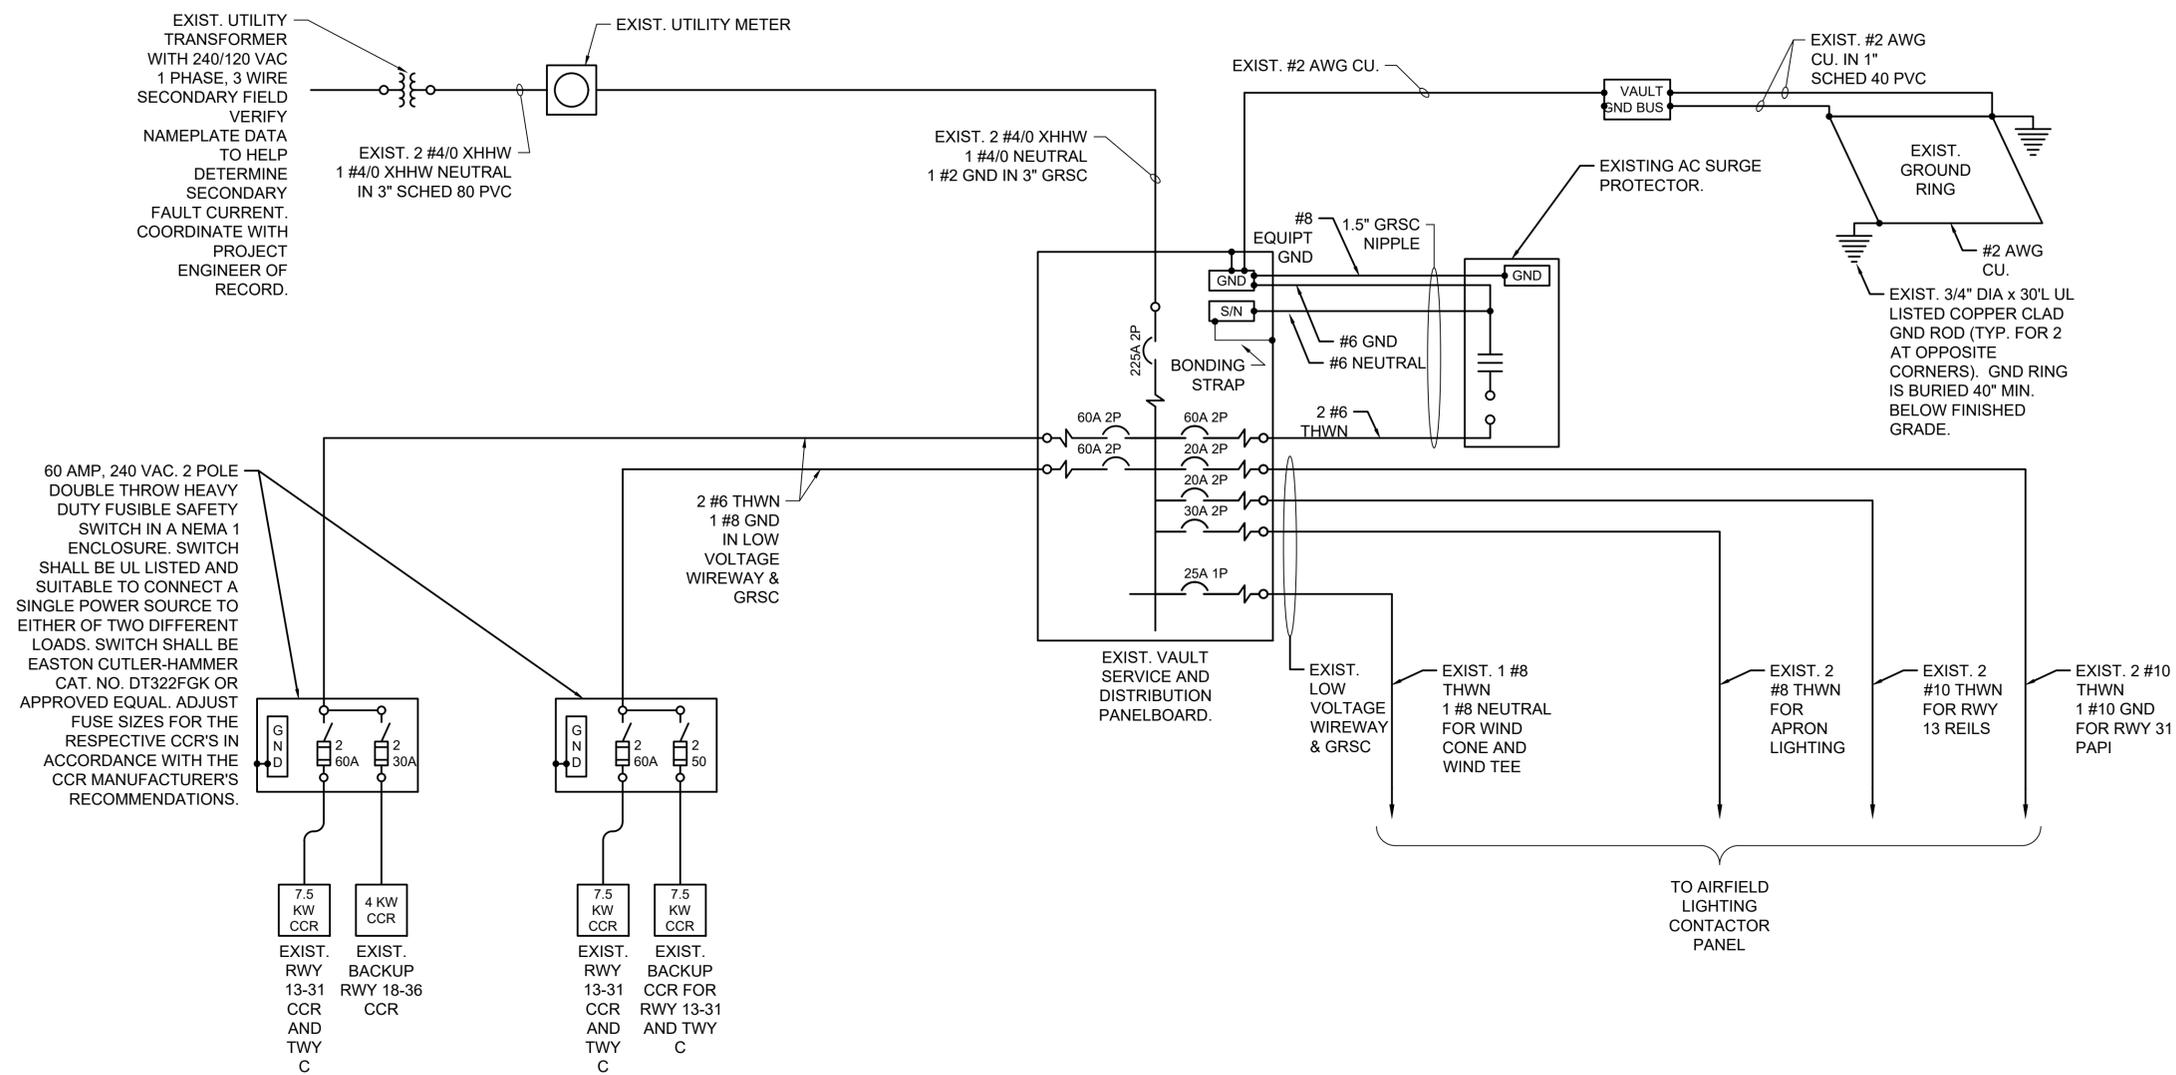

60 AMP, 240 VAC, 2 POLE DOUBLE THROW HEAVY DUTY FUSIBLE SAFETY SWITCH IN A NEMA 1 ENCLOSURE. SWITCH SHALL BE UL LISTED AND SUITABLE TO CONNECT A SINGLE POWER SOURCE TO EITHER OF TWO DIFFERENT LOADS. SWITCH SHALL BE EASTON CUTLER-HAMMER CAT. NO. DT322FGK OR APPROVED EQUAL. ADJUST FUSE SIZES FOR THE RESPECTIVE CCR'S IN ACCORDANCE WITH THE CCR MANUFACTURER'S RECOMMENDATIONS.

EXISTING ELECTRICAL ONE-LINE DIAGRAM FOR VAULT AND AIRFIELD

NOTES:

- CONTRACTOR SHALL EXAMINE THE SITE TO DETERMINE EXISTING CONDITIONS. CONTRACTOR SHALL FIELD VERIFY RESPECTIVE CIRCUITS AND POWER SOURCES PRIOR TO REMOVING, DISCONNECTING, RELOCATING, CONNECTING, OR WORKING ON THE RESPECTIVE AIRFIELD LIGHTING, NAVAID, VAULT EQUIPMENT OR OTHER DEVICE.
- ALL POWER OUTAGES, AND/OR SHUT DOWN OF EXISTING AIRFIELD LIGHTING OR OTHER SYSTEMS SHALL BE COORDINATED WITH THE AIRPORT MANAGER AND/OR AIRPORT REPRESENTATIVE. ONCE SHUT DOWN, THE CIRCUITS SHALL BE LABELED AS SUCH TO PREVENT ACCIDENTAL ENERGIZING OF THE RESPECTIVE CIRCUITS. ALL PERSONNEL SHALL FOLLOW U.S. DEPARTMENT OF LABOR OCCUPATIONAL SAFETY & HEALTH ADMINISTRATION (OSHA) 29 CFR PART 1910 OCCUPATIONAL SAFETY & HEALTH STANDARDS FOR ELECTRICAL SAFETY AND LOCKOUT/TAGOUT PROCEDURES INCLUDING, BUT NOT LIMITED TO, 29 CFR SECTION 1910.147 THE CONTROL OF HAZARDOUS ENERGY (LOCKOUT/TAGOUT).
- CONTRACTOR SHALL COMPLY WITH THE REQUIREMENTS OF FAA AC NO. 150/5370-2G (OR MOST CURRENT ISSUE) "OPERATIONAL SAFETY ON AIRPORTS DURING CONSTRUCTION".
- CONTRACTOR SHALL COMPLY WITH THE APPLICABLE REQUIREMENTS OF NFPA 70E - STANDARD FOR ELECTRICAL SAFETY IN THE WORKPLACE.
- THE RESPECTIVE PERSONNEL PERFORMING AIRFIELD LIGHTING WORK, VAULT WORK, AND/OR TESTS SHALL BE FAMILIAR WITH, AND QUALIFIED TO WORK ON, 5000 VOLT AIRFIELD LIGHTING SERIES CIRCUITS, CONSTANT CURRENT REGULATORS AND ASSOCIATED AIRPORT ELECTRICAL VAULT EQUIPMENT.
- MEGGER TEST AND RECORD EXISTING SERIES CIRCUITS AND RWY 13 REIL CKT PHASE CONDUCTORS PRIOR TO CABLE WORK AND AGAIN AFTER REIL WORK, AIRFIELD WORK, ADDITIONS, AND/OR UPGRADES HAVE BEEN COMPLETED. ALSO TEST AND RECORD SERIES CIRCUIT LOOP RESISTANCE.
- EACH CCR SHALL BE TESTED FOR PROPER OPERATION BEFORE REMOVAL WORK, DEMOLITION WORK, ELECTRICAL WORK, EXCAVATIONS, DIGGING, TRENCHING, OR ANY OTHER WORK THAT MIGHT POSSIBLY AFFECT AIRFIELD LIGHTING AND AGAIN AFTER AIRFIELD WORK AND PAPI WORK IS COMPLETED.
- ALL EXISTING AIRFIELD LIGHTING SYSTEMS, NAVAIDS, APRON LIGHTING, AND/OR OTHER AIRPORT FACILITIES (THAT ARE NOT SCHEDULED FOR REMOVAL OR REPLACEMENT) SHALL BE OPERABLE DURING NIGHTFALL WHEN THE RESPECTIVE RUNWAY IS OPEN FOR OPERATION UNLESS OTHERWISE APPROVED BY THE AIRPORT MANAGER AND/OR OTHERWISE DETAILED HEREIN. CONTRACTOR SHALL PROVIDE ALL TEMPORARY WORK AS NECESSARY TO MAINTAIN OPERATION OF THE AIRFIELD LIGHTING SYSTEMS AT NIGHTFALL. CONTRACTOR SHALL COORDINATE TRANSFER OF EXISTING AIRFIELD CIRCUITS TO MINIMIZE DOWNTIME.
- WHEN A RUNWAY IS CLOSED THE RUNWAY LIGHTING AND ASSOCIATED AIRFIELD NAVAIDS FOR THAT RUNWAY SHALL BE SHUT OFF.
- WHEN A TAXIWAY IS CLOSED THE RESPECTIVE TAXIWAY LIGHTING SHALL BE SHUT OFF
- OTHER PROJECTS MIGHT BE UNDER CONSTRUCTION PRIOR TO OR DURING THIS PROJECT. COORDINATE WORK WITH OTHER CONTRACTORS.


INSTALL RUNWAY END IDENTIFIER LIGHTS ON RUNWAY END 13
SBG: 3-17-SBGP-TBD
IDA No: C75-5140
Contract No. MA035

NO.	DATE	DESCRIPTION		
		DES	DWN	REV

ISSUE: AUGUST, 16 2024
PROJECT NO: 23A1045
CAD FILE: E-601.DWG
DESIGN BY: KNL 05/19/2024
DRAWN BY: JAP 05/02/2024
REVIEWED BY: KNL 6/10/2024
SHEET TITLE

EXISTING ELECTRICAL ONE-LINE FOR VAULT AND AIRFIELD

SEP 25, 2024 8:29 AM HALUSM0682
I:\23\JOBS\23A1045_00\CAD\AIRPORT\15HEETE-601.DWG

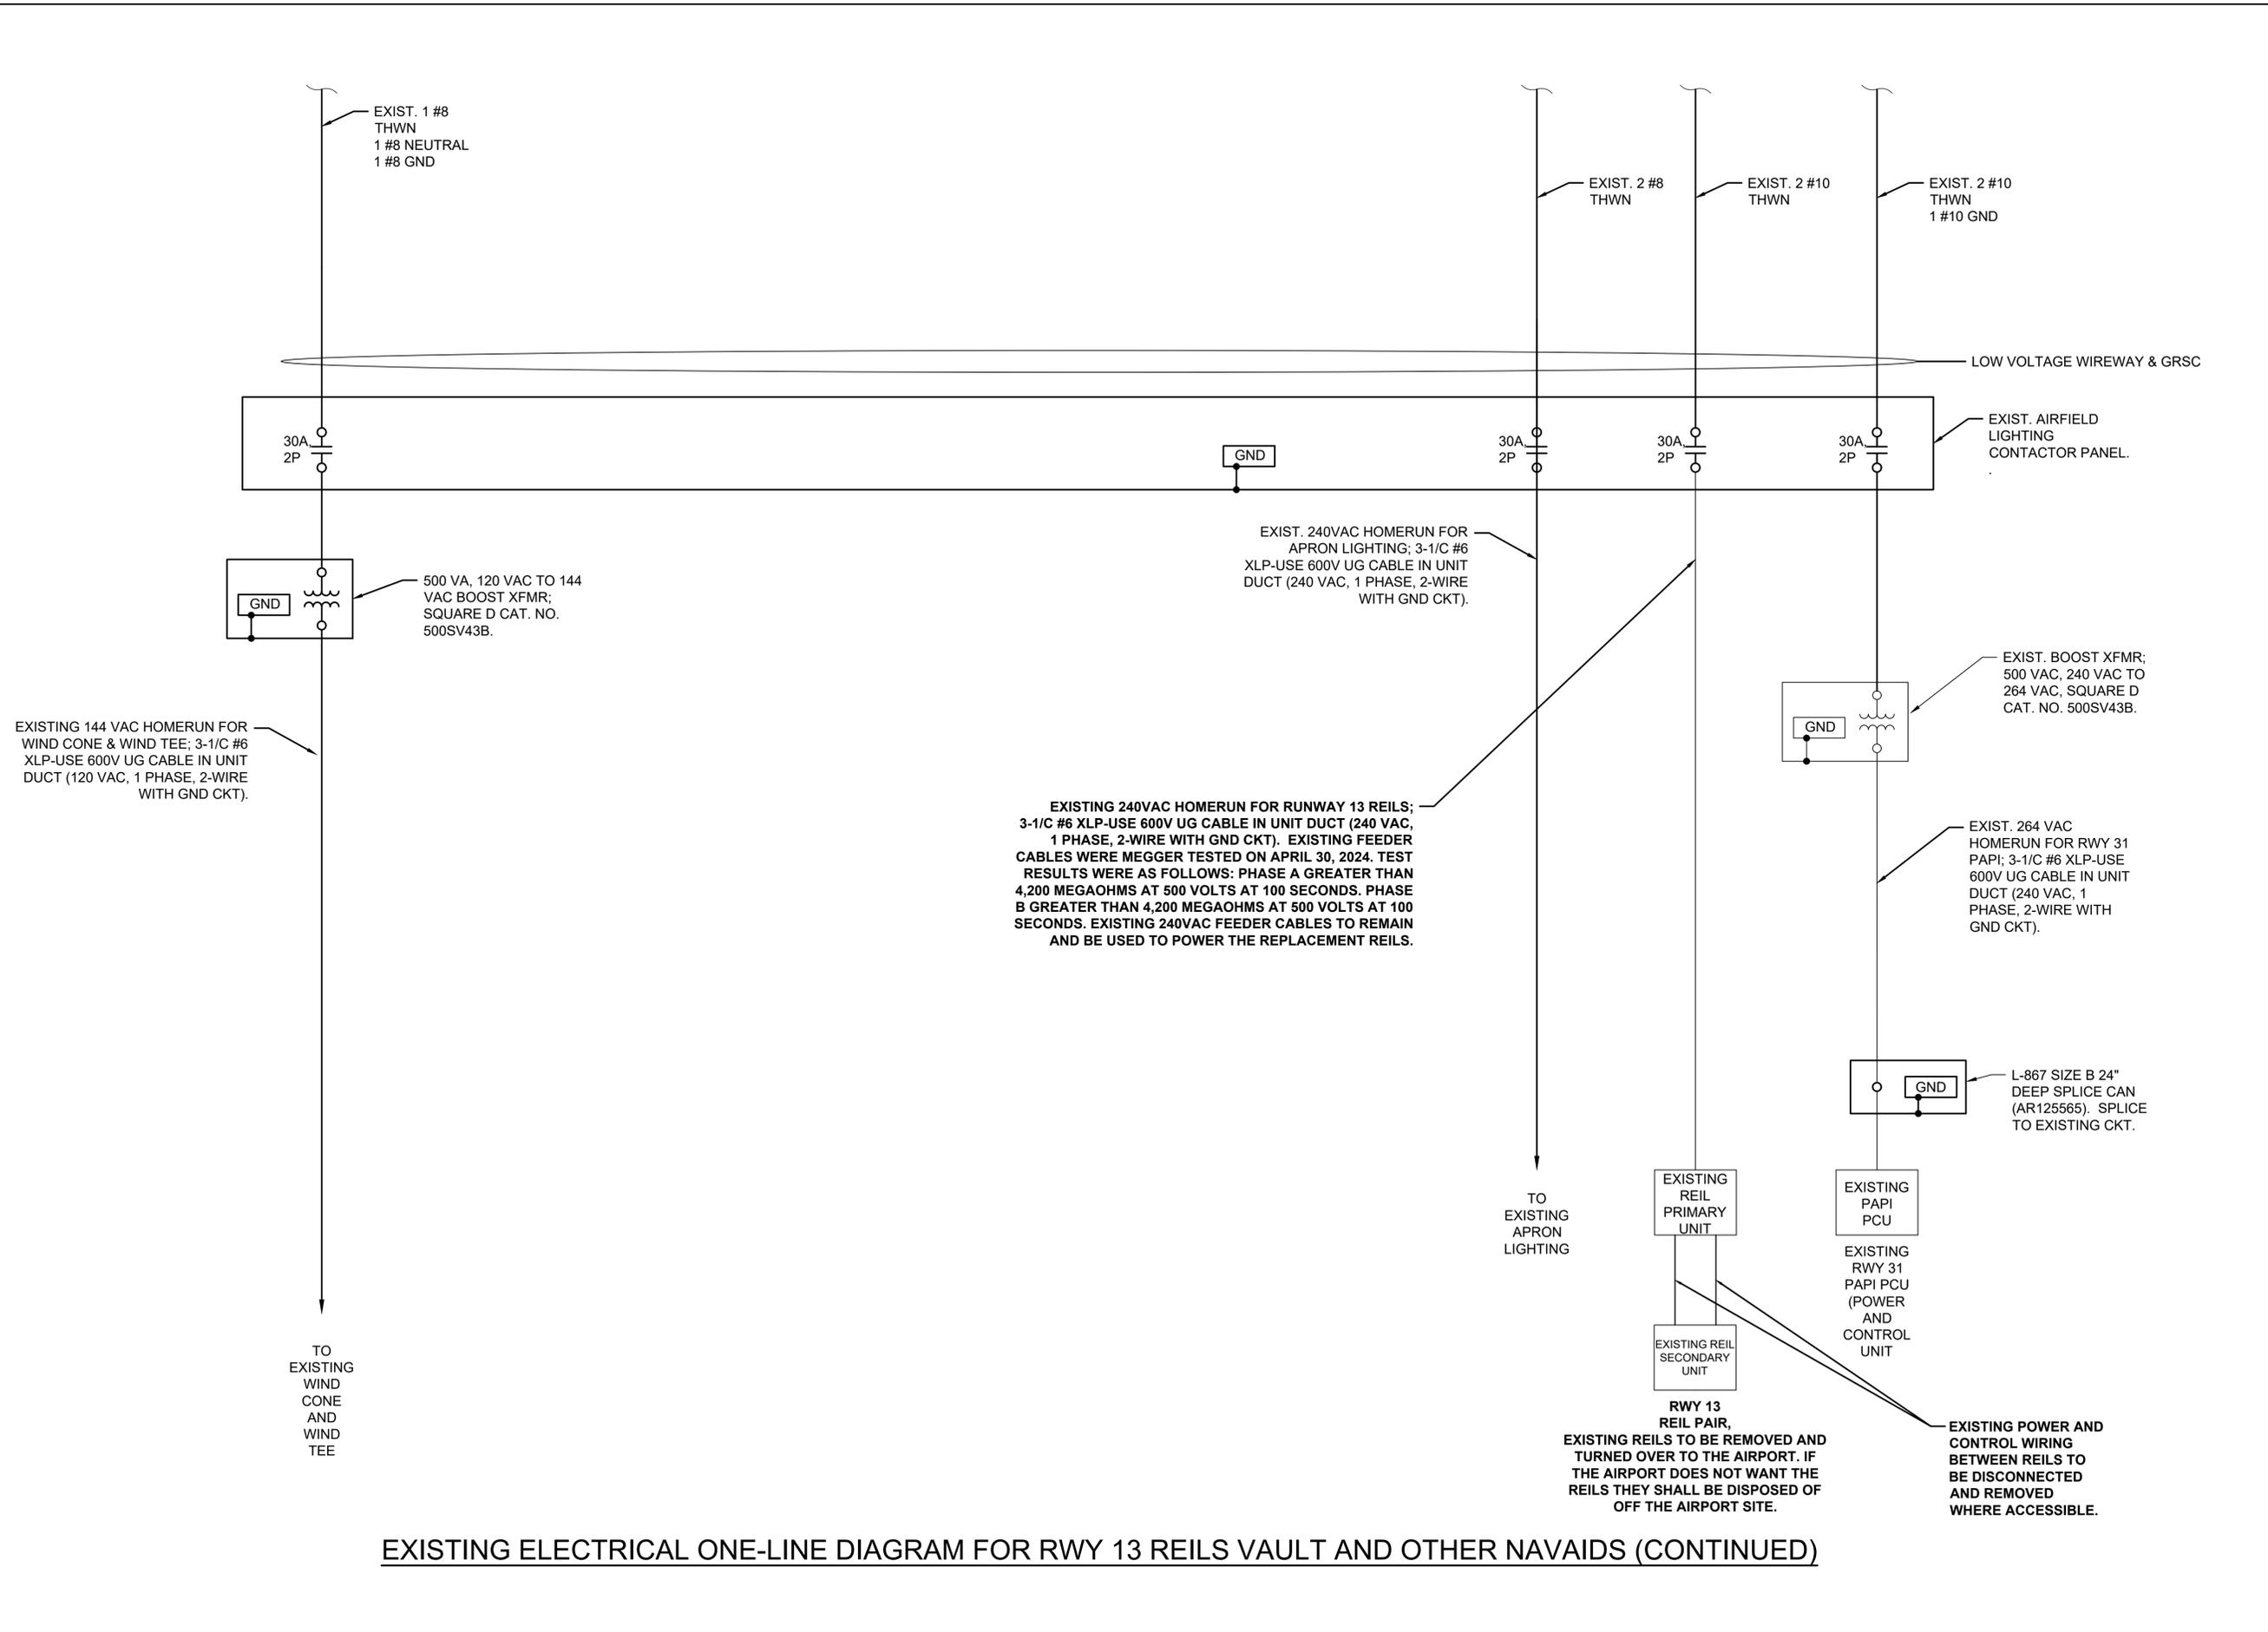

EXISTING ELECTRICAL ONE-LINE DIAGRAM FOR RWY 13 REILS VAULT AND OTHER NAVAIDS (CONTINUED)

INSTALL RUNWAY END IDENTIFIER LIGHTS ON RUNWAY END 13

SBG: 3-17-SBGP-TBD

IDA No: C75-5140

Contract No. MA035

NO.	DATE	DESCRIPTION		
		DES	DWN	REV

ISSUE: AUGUST, 16 2024
PROJECT NO: 23A1045
CAD FILE: E-601.DWG
DESIGN BY: KNL 05/19/2024
DRAWN BY: JAP 05/02/2024
REVIEWED BY: KNL 6/10/2024


SHEET TITLE

EXISTING ELECTRICAL ONE-LINE FOR RWY 13 REILS AND OTHER NAVAIDS



NOTES

1. ALL VAULT WORK, POWER OUTAGES, AND/OR SHUT DOWN OF EXISTING SYSTEMS SHALL BE COORDINATED WITH THE AIRPORT MANAGER. ONCE SHUT DOWN, THE CIRCUITS SHALL BE LABELED AS SUCH TO PREVENT ACCIDENTAL ENERGIZING OF THE RESPECTIVE CIRCUITS. ALL PERSONNEL SHALL FOLLOW U.S. DEPARTMENT OF LABOR OCCUPATIONAL SAFETY & HEALTH ADMINISTRATION (OSHA) 29 CFR PART 1910 OCCUPATIONAL SAFETY & HEALTH STANDARDS FOR ELECTRICAL SAFETY AND LOCKOUT/TAGOUT PROCEDURES INCLUDING, BUT NOT LIMITED TO, 29 CFR SECTION 1910.147 THE CONTROL OF HAZARDOUS ENERGY (LOCKOUT/TAGOUT).
2. ALL ELECTRICAL EQUIPMENT AND MATERIALS SHALL BE INSTALLED IN CONFORMANCE WITH NFPA 70 - NATIONAL ELECTRICAL CODE (NEC) MOST CURRENT ISSUE IN FORCE, THE RESPECTIVE EQUIPMENT MANUFACTURER'S DIRECTIONS AND ALL OTHER APPLICABLE LOCAL CODES, LAWS, ORDINANCES AND REQUIREMENTS IN FORCE. ANY INSTALLATIONS WHICH VOID THE U.L. LISTING, INTERTEK TESTING SERVICES VERIFICATION/ETL LISTING, (OR OTHER THIRD PARTY LISTING) AND/OR THE MANUFACTURER'S WARRANTY OF A DEVICE WILL NOT BE PERMITTED.
3. ALL CONDUCTORS/WIRING SHALL BE COPPER.
4. HIGH VOLTAGE CIRCUITS (AIRFIELD LIGHTING 5000 VOLT SERIES CIRCUITS OR OTHER CIRCUITS RATED ABOVE 600 VOLTS) AND LOW VOLTAGE CIRCUITS (RATED 600 VOLTS AND BELOW) SHALL NOT BE INSTALLED IN THE SAME WIREWAY, CONDUIT, HANDHOLE, JUNCTION BOX, OR RACEWAY.
5. EQUIPMENT AND MATERIALS NOT LABELED AS "EXISTING" ARE NEW.
6. ALL NEW VAULT WORK WILL BE CONSIDERED INCIDENTAL TO THE RESPECTIVE REIL WORK PAY ITEM AND/OR ITEM AR800564 CABLE AND CCR TESTING AND CALIBRATION PER L. SUM.
7. ALL CABLE AND CONDUIT/DUCT WORK ASSOCIATED WITH THE REILS WILL BE CONSIDERED INCIDENTAL TO THE RESPECTIVE REIL WORK PAY ITEM

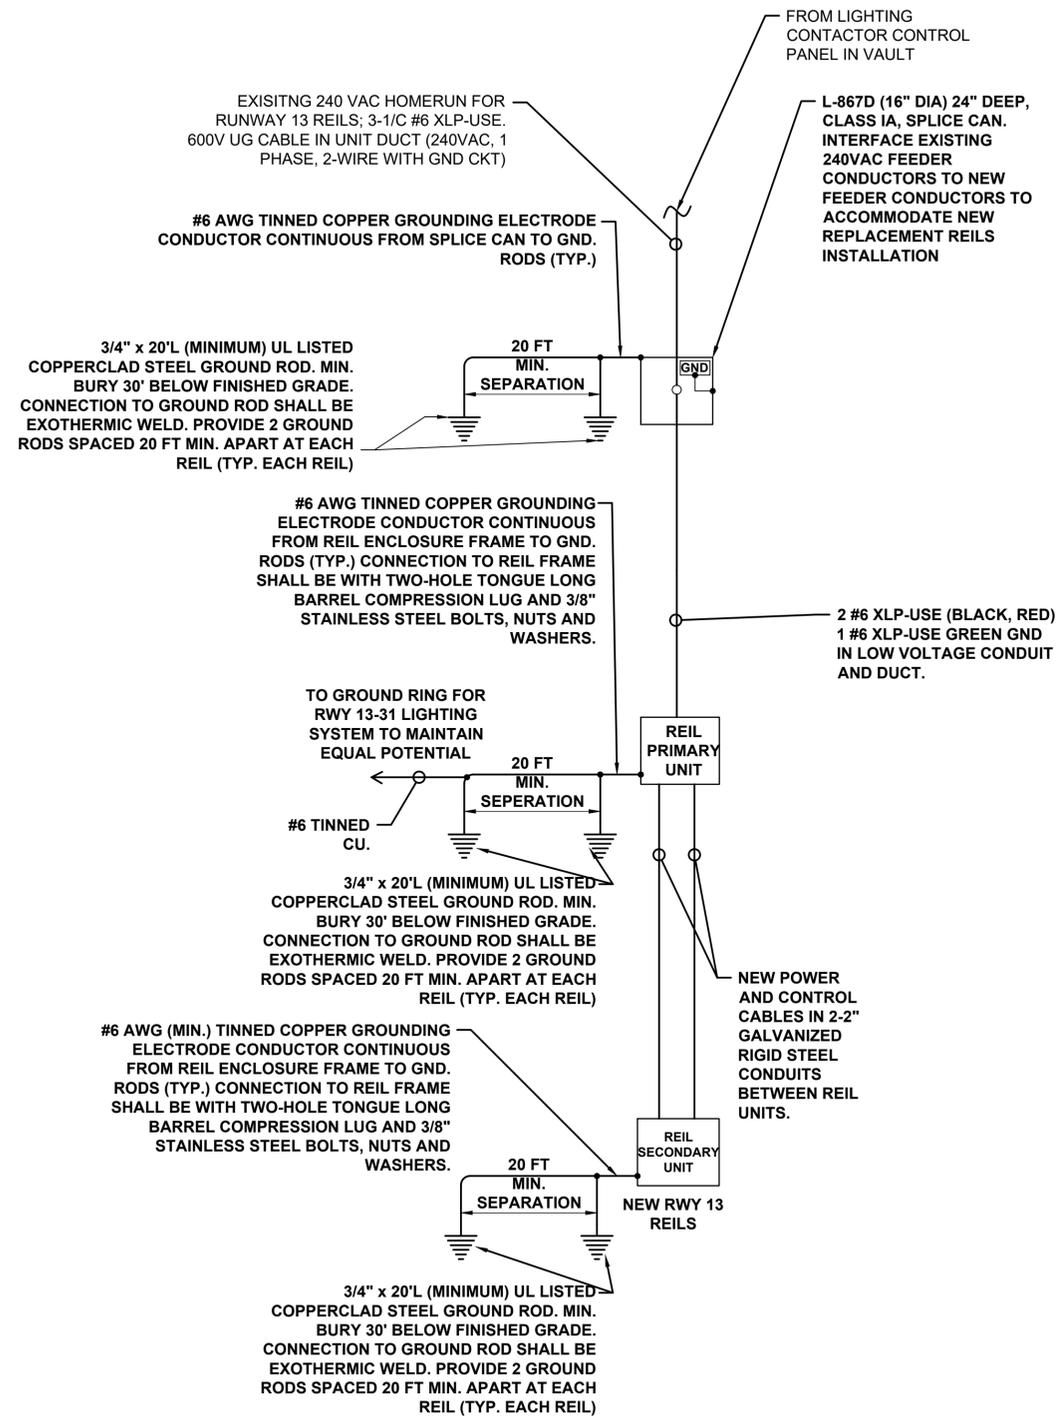

PROPOSED ELECTRICAL ONE-LINE DIAGRAM FOR RWY 13 REILS

NOT TO SCALE

INSTALL RUNWAY END IDENTIFIER LIGHTS ON RUNWAY END 13

SBG: 3-17-SBGP-TBD

IDA No: C75-5140



Contract No. MA035

NO.	DATE	DESCRIPTION		
		DES	DWN	REV

ISSUE: AUGUST, 16 2024
PROJECT NO: 23A1045
CAD FILE: E-605.DWG
DESIGN BY: KNL 05/19/2024
DRAWN BY: JAP 05/02/2024
REVIEWED BY: KNL 6/10/2024

SHEET TITLE

PROPOSED ELECTRICAL ONE-LINE FOR RWY 13 REILS

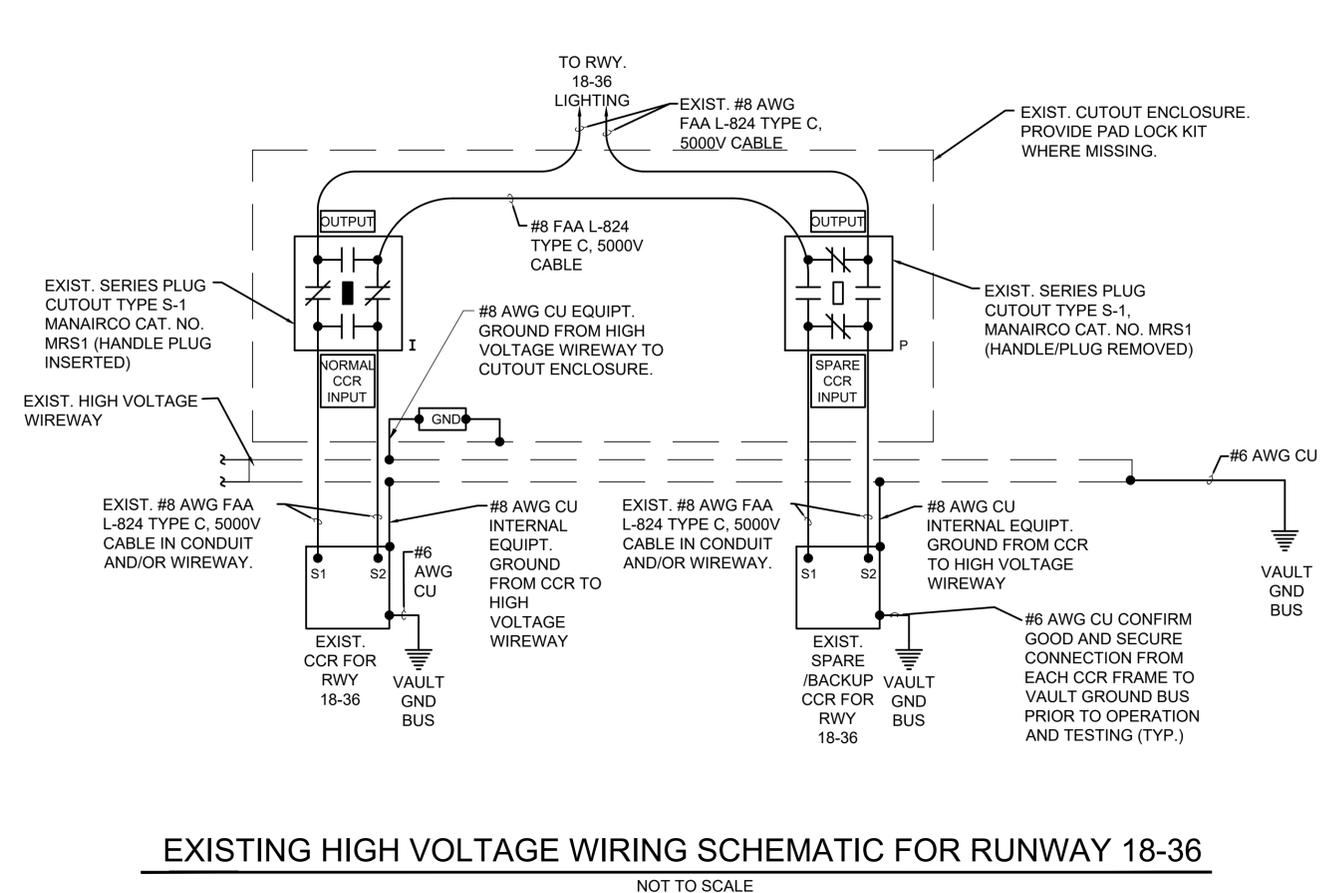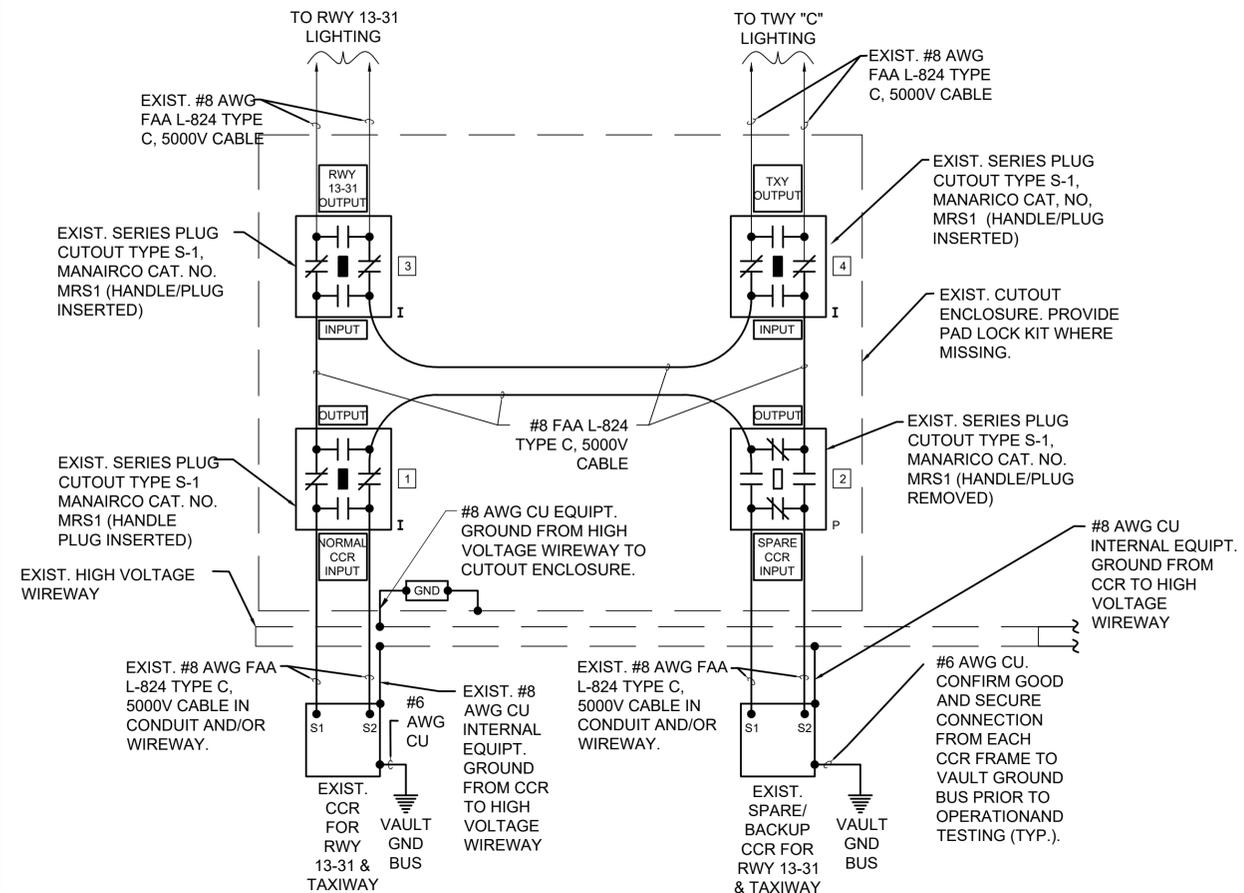

EXISTING HIGH VOLTAGE WIRING SCHEMATIC FOR RUNWAY 18-36
NOT TO SCALE

EXISTING HIGH VOLTAGE WIRING SCHEMATIC FOR RUNWAY 13-31 & TAXIWAY
NOT TO SCALE

EXISTING HIGH VOLTAGE WIRING SCHEMATIC

NOTES:

- KEEP ALL WORK, POWER OUTAGES, AND/OR SHUT DOWN OF EXISTING SYSTEMS COORDINATED WITH THE AIRPORT MANAGER/DIRECTOR AND RESIDENT PROJECT REPRESENTATIVE. ONCE SHUT DOWN, THE CIRCUITS SHALL BE LABELED AS SUCH TO PREVENT ACCIDENTAL ENERGIZING OF THE RESPECTIVE CIRCUITS. ALL PERSONNEL SHALL FOLLOW U.S. DEPARTMENT OF LABOR OCCUPATIONAL SAFETY & HEALTH ADMINISTRATION (OSHA) 29 CFR PART 1910 OCCUPATIONAL SAFETY & HEALTH STANDARDS FOR ELECTRICAL SAFETY AND LOCKOUT/TAGOUT PROCEDURES INCLUDING, BUT NOT LIMITED TO, 29 CFR SECTION 1910.147 THE CONTROL OF HAZARDOUS ENERGY (LOCKOUT/TAGOUT).
- EXAMINE THE SITE TO CONFIRM AND FIELD VERIFY EXISTING SITE CONDITIONS.
- VERIFY RESPECTIVE CIRCUITS AND POWER SOURCES FOR RESPECTIVE SYSTEMS PRIOR TO REMOVING, DISCONNECTING, WORKING ON, RELOCATING, RECONNECTING, AND/OR INSTALLING THE RESPECTIVE AIRFIELD LIGHTING, TAXI SIGN, NAVAID, OR OTHER DEVICES. THE CONTRACTOR WILL NEED TO EXERCISE CAUTION WHEN WORKING IN THE VAULT AND ON THE AIRFIELD. CONTRACTOR SHALL REPORT ANY VARIATIONS, DEFICIENCIES, AND/OR APPARENT SAFETY CONCERNS TO THE PROJECT ENGINEER AND THE RESIDENT ENGINEER. CONTRACTOR SHALL FOLLOW LOCKOUT/TAGOUT PROCEDURES FOR SAFETY OF PERSONNEL. CONTRACTOR SHALL FURNISH AND INSTALL LOCKOUT/TAGOUT KITS PER SPECIFICATIONS.
- IDENTIFY EACH RESPECTIVE CIRCUIT PRIOR TO PERFORMING WORK ON THAT CIRCUIT.
- NEVER PULL A CUTOUT OR DISCONNECT AN L-823 CABLE CONNECTION WITH THE CIRCUIT ENERGIZED. SHUTOFF CIRCUITS PRIOR TO PULLING A SERIES PLUG CUTOUT OR DISCONNECTING A CABLE.
- THE RESPECTIVE PERSONNEL PERFORMING AIRFIELD LIGHTING WORK, VAULT WORK, AND/OR TESTS SHALL BE FAMILIAR WITH, AND QUALIFIED TO WORK ON, 5000 VOLT AIRFIELD LIGHTING SERIES CIRCUITS, CONSTANT CURRENT REGULATORS, AND ASSOCIATED AIRPORT ELECTRICAL VAULT EQUIPMENT.
- EXERCISE CAUTION, PRACTICE SAFETY, AND DISCONNECT THE SERIES CIRCUITS FROM THE RESPECTIVE CONSTANT CURRENT REGULATORS, AS APPLICABLE WHEN PERFORMING WORK ON THE AIRFIELD LIGHTING OR WORK THAT MIGHT AFFECT THE AIRFIELD LIGHTING. CONTRACTOR SHALL MAKE NECESSARY ARRANGEMENTS TO DISCONNECT POWER AND LOCKOUT CIRCUITS FOR PROTECTION OF PERSONNEL.
- OVERSEE AND CONDUCT TESTS FOR AREAS OF WORK WHERE THE RESPECTIVE CIRCUITS MIGHT BE AFFECTED. MEGGER TEST AND RECORD EXISTING SERIES CIRCUITS (WITH A CABLE INSULATION TESTER) PRIOR TO CABLE WORK OR ANY OTHER WORK THAT MIGHT POSSIBLY AFFECT AIRFIELD LIGHTING SYSTEMS, AND AGAIN AFTER AIRFIELD LIGHTING MODIFICATIONS, ADDITIONS, UPGRADES AND/OR OTHER WORK HAS BEEN COMPLETED. PROVIDE 5KV INSULATION TESTER FOR 5,000 VOLT SERIES CIRCUIT CABLES. ALSO TEST AND RECORD SERIES CIRCUIT LOOP RESISTANCE WITH AN OHMMETER. PROVIDE COPY OF TEST RESULTS TO THE PROJECT ENGINEER OF RECORD (EOR) WITHIN 5 DAYS OF CONDUCTING TESTS.
- RESPECTIVE CCR'S SHALL BE TESTED FOR PROPER OPERATION BEFORE REMOVAL WORK, MODIFICATIONS, ADDITIONS AND/OR ANY AIRFIELD WORK THAT MIGHT AFFECT LIGHTING CIRCUITS AND AGAIN AFTER THE AIRFIELD WORK AND ADDITIONS HAVE BEEN COMPLETED. CONTRACTOR SHALL TEST AND RECORD THE INPUT CURRENT AND OUTPUT CURRENT FOR EACH CONSTANT CURRENT REGULATOR IN THE AUTOMATIC AND MANUAL MODES OF OPERATION. PROVIDE A TRUE RMS AMMETER FOR CURRENT MEASUREMENTS. CONTRACTOR SHALL REPORT CONCERNS AND/OR DEFICIENCIES TO THE RESIDENT PROJECT REPRESENTATIVE AND THE ENGINEER OF RECORD (EOR). WRITTEN TEST RESULTS SHALL BE PROVIDED TO THE RESIDENT ENGINEER AND THE PROJECT ENGINEER OF RECORD (EOR).

LEGEND

"I"	DENOTES PLUG CUTOUT WITH PLUG INSERTED
"P"	DENOTES PLUG CUTOUT WITH PLUG PULLED
"CCR"	DENOTES CONSTANT CURRENT REGULATOR

INSTALL RUNWAY END IDENTIFIER LIGHTS ON RUNWAY END 13

SBG: 3-17-SBGP-TBD

IDA No: C75-5140


Contract No. MA035

NO.	DATE	DESCRIPTION		
		DES	DWN	REV

ISSUE: AUGUST, 16 2024
PROJECT NO: 23A1045
CAD FILE: E-602.DWG
DESIGN BY: KNL 05/19/2024
DRAWN BY: JAP 05/02/2024
REVIEWED BY: LDH 06/15/2024

SHEET TITLE

EXISTING HIGH VOLTAGE WIRING SCHEMATICS FOR RWY 13-31 AND TWY C

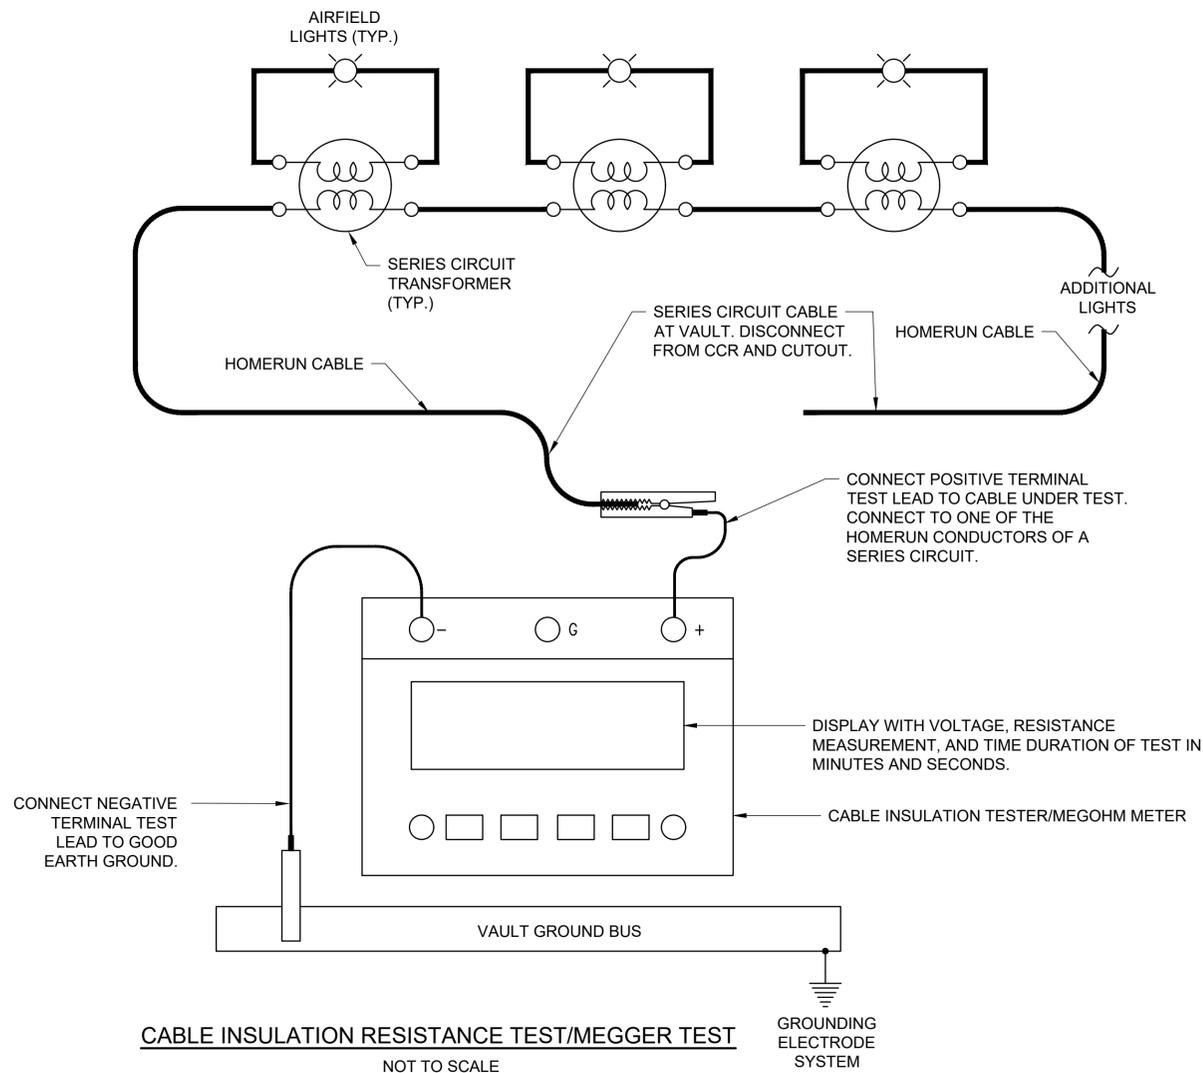


CABLE INSULATION RESISTANCE TEST/MEGGER TEST

NOT TO SCALE

CABLE INSULATION RESISTANCE TEST (MEGGER TEST) NOTES

- PRIOR TO BEGINNING EXCAVATIONS, AIRFIELD LIGHTING MODIFICATIONS, CABLE INSTALLATION, AND/OR ANY OTHER WORK THAT MIGHT POSSIBLY AFFECT AIRFIELD LIGHTING CIRCUITS, ALL EXISTING SERIES CIRCUIT LIGHTING CABLES SHALL BE MEGGER TESTED WITH AN INSULATION RESISTANCE TESTER AND RECORDED AT THE RESPECTIVE AIRPORT ELECTRICAL VAULT.
- AFTER AIRFIELD LIGHTING MODIFICATIONS, ADDITIONS, UPGRADES, AND/OR OTHER WORK AND ADDITIONS HAVE BEEN COMPLETED ALL EXISTING SERIES CIRCUIT LIGHTING CABLES SHALL BE MEGGER TESTED WITH AN INSULATION RESISTANCE TESTER AND RECORDED AT THE RESPECTIVE AIRPORT ELECTRICAL VAULT.
- THE CONTRACTOR IS RESPONSIBLE TO EMPLOY THE SERVICES OF PERSONNEL QUALIFIED, FAMILIAR WITH, AND TRAINED TO PERFORM THE RESPECTIVE TESTS, AND QUALIFIED TO WORK ON 5000 VOLT AIRFIELD LIGHTING SERIES CIRCUITS, CONSTANT CURRENT REGULATORS, AND ASSOCIATED AIRPORT ELECTRICAL VAULT EQUIPMENT.
- INSULATION RESISTANCE TESTING EQUIPMENT FOR USE WITH 5,000 VOLT SERIES CIRCUIT CABLES SHALL USE AN INSULATION RESISTANCE TESTER CAPABLE OF TESTING THE CABLES AT 5,000 VOLTS. OLDER SERIES CIRCUIT CABLES AND/OR CABLES IN POOR CONDITION MAY REQUIRE THE TEST VOLTAGE TO BE PERFORMED AT A VOLTAGE LOWER THAN 5,000 VOLTS (EXAMPLE 1,000 VOLTS, 500 VOLTS, OR LESS THAN 500 VOLTS). THE RESPECTIVE TEST VOLTAGE SHALL BE RECORDED FOR EACH CABLE INSULATION RESISTANCE TEST RESULT.
- INSULATION RESISTANCE TESTING EQUIPMENT FOR USE WITH 600 VOLT RATED CABLES SHALL USE A 500 VOLT INSULATION RESISTANCE TESTER. THE RESPECTIVE TEST VOLTAGE SHALL BE RECORDED FOR EACH CABLE INSULATION RESISTANCE TEST RESULT.
- IT IS RECOMMENDED TO USE THE SAME INSULATION RESISTANCE TEST EQUIPMENT THROUGHOUT THE PROJECT TO ENSURE RELIABLE COMPARATIVE READINGS AT THE BEGINNING OF THE PROJECT AND AT THE COMPLETION OF THE PROJECT.
- DISCONNECT THE AIRFIELD LIGHTING SERIES CIRCUIT CABLES FROM THE CONSTANT CURRENT REGULATOR WHEN PERFORMING CABLE INSULATION RESISTANCE TESTS (MEGGER TESTS). TEST THE CABLES THAT GO TO THE AIRFIELD FOR THE RESPECTIVE AIRFIELD LIGHTING SERIES CIRCUIT. CONNECT THE CABLE INSULATION RESISTANCE TESTER TO ONE OF THE AIRFIELD LIGHTING SERIES CIRCUIT CABLES AND TO A GOOD GROUND IN THE AIRPORT ELECTRICAL VAULT SUCH AS THE AIRPORT VAULT GROUND BUS. CONDUCT THE CABLE INSULATION RESISTANCE TEST ON EACH RESPECTIVE CABLE FOR NOT LESS THAN 90 SECONDS. RECORD THE TEST RESULTS AT THE END OF THE TIME DURATION FOR THE TEST.
- FAA ADVISORY CIRCULAR 150/5340-26C MAINTENANCE OF AIRPORT VISUAL AID FACILITIES PROVIDES GUIDANCE ON INSULATION RESISTANCE TESTS. ALSO REFER TO THE USER MANUAL FOR THE RESPECTIVE CABLE INSULATION RESISTANCE TESTER. REASONABLY NEW SERIES CIRCUIT CABLES AND TRANSFORMERS WITH GOOD CONNECTIONS SHOULD READ 500 MEGA-OHMS TO 1,000 MEGA-OHMS OR HIGHER. THE READINGS SHOULD DECREASE WITH AGE. THE RESISTANCE VALUE DECLINES OVER THE SERVICE LIFE OF THE CIRCUIT; A 10-20 PERCENT DECLINE PER YEAR MAY BE CONSIDERED NORMAL. A YEARLY DECLINE OF 50 PERCENT (4 PERCENT MONTHLY) OR GREATER INDICATES THE EXISTENCE OF A PROBLEM, SUCH AS A HIGH RESISTANCE GROUND, SERIOUS DETERIORATION OF THE CIRCUIT INSULATION, LIGHTNING DAMAGE, BAD CONNECTIONS, BAD SPLICES, CABLE INSULATION DAMAGE, OR OTHER FAILURE. FAA ADVISORY CIRCULAR 150/5340-26C NOTES "GENERALLY SPEAKING, ANY CIRCUIT THAT MEASURES LESS THAN 1 MEGOHM IS CERTAINLY DESTINED FOR RAPID FAILURE." AIRFIELD LIGHTING SERIES CIRCUITS WITH CABLE INSULATION READINGS OF LESS THAN 1 MEGOHM ARE NOT UNCOMMON FOR OLDER CIRCUITS THAT ARE 20 YEARS OR MORE OF AGE.
- BASED ON INFORMATION IN FAA AC NO. 150/5340-26C MAINTENANCE OF AIRPORT VISUAL AID FACILITIES, THE CABLE INSULATION RESISTANCE VALUE INEVITABLY DECLINES OVER THE SERVICE LIFE OF THE CIRCUIT; A 10-20 PERCENT DECLINE PER YEAR MAY BE CONSIDERED NORMAL. IN THE EVENT THAT THE CABLE INSULATION RESISTANCE READINGS HAVE DECLINED MORE THAN 2 PERCENT PER MONTH IT MIGHT INDICATE CABLE DAMAGE DUE TO LIGHTNING OR DAMAGE AS A RESULT OF CONTRACTOR OPERATIONS. WHERE THE CABLE INSULATION RESISTANCE READINGS HAVE DECLINED MORE THAN 2 PERCENT PER MONTH OVER THE PROJECT CONSTRUCTION DURATION AS A RESULT OF CONTRACTOR OPERATIONS, CONTRACTOR WILL NEED TO INVESTIGATE, ADDRESS, AND REPAIR THE RESPECTIVE CABLE CIRCUITS.

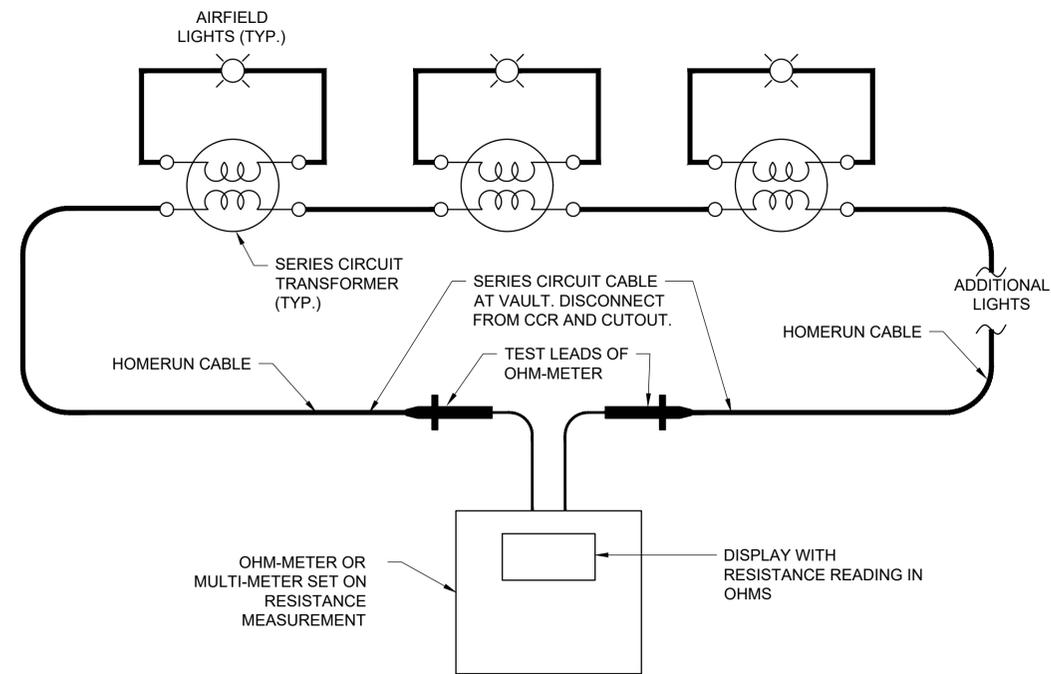

MEASURE RESISTANCE OF SERIES CIRCUIT LOOP.

NOT TO SCALE

SERIES CIRCUIT LOOP RESISTANCE MEASUREMENT NOTES

- PRIOR TO BEGINNING EXCAVATIONS, AIRFIELD LIGHTING MODIFICATIONS, CABLE INSTALLATION, AND/OR ANY OTHER WORK THAT MIGHT POSSIBLY AFFECT AIRFIELD LIGHTING CIRCUITS, THE RESPECTIVE SERIES CIRCUIT CABLE LOOPS SHALL HAVE THE RESISTANCE MEASURED WITH AN OHMMETER AND RECORDED FOR EACH CIRCUIT AT THE VAULT.
- AFTER AIRFIELD LIGHTING MODIFICATIONS, ADDITIONS, UPGRADES, AND/OR OTHER WORK AND ADDITIONS HAVE BEEN COMPLETED THE RESPECTIVE SERIES CIRCUIT CABLE LOOPS SHALL HAVE THE RESISTANCE MEASURED WITH AN OHMMETER AND RECORDED FOR EACH CIRCUIT AT THE VAULT.
- ALL EXISTING SERIES CIRCUIT CABLE LOOPS SHALL HAVE THE RESISTANCE MEASURED WITH AN OHMMETER AND RECORDED FOR EACH CIRCUIT AT THE VAULT. THE RESISTANCE OF THE SERIES CIRCUIT LOOP WITH CONNECTIONS USING #8 AWG COPPER CONDUCTOR SHOULD BE APPROXIMATELY 0.8 TO 1 OHM PER THOUSAND FEET OF CABLE LENGTH. THE RESISTANCE OF THE SERIES CIRCUIT LOOP WITH CONNECTIONS USING #6 AWG COPPER CONDUCTOR SHOULD BE APPROXIMATELY 0.5 TO 0.7 OHM PER THOUSAND FEET OF CABLE LENGTH. THE NUMBER OF SERIES CIRCUIT TRANSFORMERS AND CONNECTIONS WILL AFFECT THE OVERALL RESISTANCE OF THE SERIES CIRCUIT LOOP AND THEREFORE THE MEASUREMENTS MIGHT BE SLIGHTLY HIGHER THAN THE CALCULATED RESISTANCE FOR THE RESPECTIVE LENGTH OF CABLE.

INSTALL RUNWAY END IDENTIFIER LIGHTS ON RUNWAY END 13

SBG: 3-17-SBGP-TBD

IDA No: C75-5140

Contract No. MA035

NO.	DATE	DESCRIPTION		
		DES	DWN	REV

ISSUE: AUGUST, 16 2024
PROJECT NO: 23A1045
CAD FILE: E-604.DWG
DESIGN BY: KNL 05/19/2024
DRAWN BY: JAP 05/02/2024
REVIEWED BY: KNL 6/10/2024

SHEET TITLE

SERIES CIRCUIT CABLE TESTING DETAILS



LEGEND PLATE SCHEDULE	
DEVICE	LABEL
UTILITY METERING BASE	MAX AVAILABLE FAULT CURRENT AT UTILITY XFMR SECONDARY WAS CALCULATED TO BE _____ AMPS LINE TO LINE AND _____ AMPS LINE TO NUETRAL ON (DATE)
VAULT SERVICE AND DISTRIBUTION PANEL	MAX AVAILABLE FAULT CURRENT AT UTILITY XFMR SECONDARY WAS CALCULATED TO BE _____ AMPS LINE TO LINE AND _____ AMPS LINE TO NUETRAL ON (DATE)
VAULT SERVICE AND DISTRIBUTION PANEL	CONDUCTOR COLOR CODING SHALL BE AS FOLLOWS: PHASE A - BLACK PHASE B - RED NEUTRAL - WHITE GROUND - GREEN
TOP OF PRIMARY CCR FOR RWY 13-31 AND TWY C	KEEP CLEAR DO NOT STORE MATERIALS ON TOP OF CCR
TOP OF BACKUP/SPARE CCR FOR RWY 13-31 AND TWY C	KEEP CLEAR DO NOT STORE MATERIALS ON TOP OF CCR
TOP OF PRIMARY CCR FOR RWY 18-36	KEEP CLEAR DO NOT STORE MATERIALS ON TOP OF CCR
TOP OF BACKUP/SPARE CCR FOR RWY 18-36	KEEP CLEAR DO NOT STORE MATERIALS ON TOP OF CCR
RUNWAY 13 REIL PRIMARY UNIT	RWY 13 PRIMARY REIL POWERED BY VAULT SERVICE AND DIST. PANEL SHUT OFF POWER @ VAULT BEFORE SERVICING
RUNWAY 13 REIL SECONDARY UNIT	RWY 13 SECONDARY REIL POWERED BY VAULT SERVICE AND DIST. PANEL SHUT OFF POWER @ VAULT BEFORE SERVICING

ARC FLASH RISK LABELS	
EQUIPMENT	LABEL
UTILITY METERING BASE	WARNING ARC FLASH HAZARD APPROPRIATE PERSONAL PROTECTIVE EQUIPMENT IS REQUIRED NOMINAL VOLTAGE: 120/240 VAC, 1 PHASE, 3-WIRE ARC FLASH BOUNDARY: 19 INCHES ARC-FLASH PPE CATEGORY; 1
VAULT SERVICE AND DISTRIBUTION PANEL	WARNING ARC FLASH HAZARD APPROPRIATE PERSONAL PROTECTIVE EQUIPMENT IS REQUIRED NOMINAL VOLTAGE: 120/240 VAC, 1 PHASE, 3-WIRE ARC FLASH BOUNDARY: 19 INCHES ARC-FLASH PPE CATEGORY; 1
LIGHTING CONTACTOR PANEL	WARNING ARC FLASH HAZARD APPROPRIATE PERSONAL PROTECTIVE EQUIPMENT IS REQUIRED NOMINAL VOLTAGE: 120/240 VAC, 1 PHASE, 3-WIRE ARC FLASH BOUNDARY: 19 INCHES ARC-FLASH PPE CATEGORY; 1
DTFSS FOR RWY 18-36 CCRS	WARNING ARC FLASH HAZARD APPROPRIATE PERSONAL PROTECTIVE EQUIPMENT IS REQUIRED NOMINAL VOLTAGE: 240 VAC, 1 PHASE, 2-WIRE ARC FLASH BOUNDARY: 19 INCHES ARC-FLASH PPE CATEGORY; 1
DTFSS FOR RWY 13-31 AND TWY C CCRS	WARNING ARC FLASH HAZARD APPROPRIATE PERSONAL PROTECTIVE EQUIPMENT IS REQUIRED NOMINAL VOLTAGE: 240 VAC, 1 PHASE, 2-WIRE ARC FLASH BOUNDARY: 19 INCHES ARC-FLASH PPE CATEGORY; 1
RELAY INTERFACE PANEL	WARNING ARC FLASH HAZARD APPROPRIATE PERSONAL PROTECTIVE EQUIPMENT IS REQUIRED NOMINAL VOLTAGE: 120/240 VAC, 1 PHASE, 3-WIRE ARC FLASH BOUNDARY: 19 INCHES ARC-FLASH PPE CATEGORY; 1

NOTE: LABELS ARE BASED ON FAULT CURRENT FROM UTILITY TRANSFORMER THAT IS LESS THAN 25,000 AMPS AT 240 VAC.

NOTES:

- LEGEND PLATES SHALL BE WEATHERPROOF ENGRAVED PLASTIC OR PHENOLIC MATERIAL, 1/4" HIGH BLACK LETTERS ON A WHITE BACKGROUND UNLESS NOTED OTHERWISE. SECURE WITH WEATHERPROOF ADHESIVE AND MACHINE SCREWS. FURNISH ADDITIONAL LEGEND PLATES WHERE REQUIRED BY CODE, FOR ADDITIONAL EQUIPMENT, AS DETAILED HEREIN ON THE PLANS, AND AS NOTED IN THE SPECIAL PROVISION SPECIFICATIONS.
- FURNISH & INSTALL A WEATHERPROOF WARNING LABEL FOR EACH SAFETY SWITCH, PANELBOARD, LOAD CENTER, CUTOFF, & CONTROL PANEL TO WARN PERSONS OF POTENTIAL ELECTRIC ARC FLASH HAZARDS, PER THE REQUIREMENTS OF NEC 110.16 "ARC-FLASH HAZARD WARNING".
- FAULT CURRENT INFORMATION TO BE PROVIDED BY SERVING ELECTRIC UTILITY COMPANY OR FROM DATA OBTAINED FROM UTILITY TRANSFORMER NAMEPLATE. CONTACT PROJECT ENGINEER OF RECORD TO CONFIRM FAULT CURRENT CALCULATIONS.
- CONTRACTOR SHALL PROVIDE APPROPRIATE LABELS ON ELECTRICAL EQUIPMENT, IN ACCORDANCE WITH NFPA 70E ARTICLE 130 WORK INVOLVING ELECTRICAL HAZARDS, PART 130.5 ARC FLASH RISK ASSESSMENT, (H) EQUIPMENT LABELING. WHERE MAXIMUM CALCULATED FAULT CURRENT EXCEEDS 25,000 AMPS CONTACT PROJECT ENGINEER.
- "EQUIPMENT LABELING, FIRE EXTINGUISHER, FIRE STOP MATERIAL, AND LOCKOUT/TAGOUT KIT AND PROCEDURES WILL BE CONSIDERED INCIDENTAL TO ITEM AR800564 "CABLE AND CCR (CONSTANT CURRENT REGULATOR) TESTING AND CALIBRATION" PER LUMP SUM".
- PROVIDE LOCKOUT STATION WITH 10 LOCKOUT PADLOCKS, EACH WITH A DIFFERENT KEY, 5 LOCKOUT HASPS TO ACCOMMODATE MULTIPLE PADLOCKS AND 50 LOCKOUT TAGS, IN ACCORDANCE WITH OSHA STANDARD 1910.147.
- FURNISH AND INSTALL A 10LB UL RATING 1A:10B:C HALOTRON FIRE EXTINGUISHER SUITABLE FOR USE ON CLASS A,B,C FIRES, IN THE VAULT SHELTER. INCLUDE WALL MOUNTING BRACKET. CONFIRM MODEL NUMBERS WITH THE RESPECTIVE FIRE EXTINGUISHER MANUFACTURER. THIS SHALL REPLACE THE EXISTING FIRE EXTINGUISHER.
- FURNISH AND INSTALL A UL RATED, 10 POUND CARBON DIOXIDE FIRE EXTINGUISHER SUITABLE FOR USE ON CLASS C FIRES IN THE VAULT SHELTER; AMEREX MODEL 330, BUCKEYE MODEL 10 CD, OR APPROVED EQUAL. INCLUDE WALL MOUNTING BRACKET. CONFIRM MODEL NUMBERS WITH THE RESPECTIVE FIRE EXTINGUISHER MANUFACTURER. THIS SHALL REPLACE THE EXISTING FIRE EXTINGUISHER.



"DANGER - HIGH VOLTAGE UNAUTHORIZED PERSONNEL KEEP OUT" SIGN

PROVIDE WEATHERPROOF WARNING SIGN FOR EACH DOOR TO AIRPORT ELECTRICAL VAULT LABELED "DANGER - HIGH VOLTAGE UNAUTHORIZED PERSONNEL KEEP OUT" PER THE REQUIREMENTS OF NEC 110.34 (C). SIGN SHALL BE APPROXIMATELY 10"H X 14"W. NEW SIGNS SHALL REPLACE EXISTING SIGNS ON VAULT DOORS

INSTALL RUNWAY END IDENTIFIER LIGHTS ON RUNWAY END 13

SBG: 3-17-SBGP-TBD

IDA No: C75-5140

Contract No. MA035

NO.	DATE	DESCRIPTION		
		DES	DWN	REV

ISSUE: AUGUST, 16 2024
PROJECT NO: 23A1045
CAD FILE: E-603.DWG
DESIGN BY: KNL 05/19/2024
DRAWN BY: JAP 05/02/2024
REVIEWED BY: KNL 6/10/2024

SHEET TITLE

LEGEND PLATE SCHEDULES