



SEQUENCE OF OPERATIONS

STAGE II -B

NOTE: See the Special Provision entitled "Working Restrictions & Staging Notes", (No. 5) for a description of the permitted hours of construction work for this stage.

PURPOSE

Because of high traffic volumes, the traffic control in Stages II-A & II-B is needed solely for the placement of pavement marking tape type III, redefining the EB and center lanes in preparation for Stages III-A & III-B.

CONSTRUCTION



Remove existing pavement markings on the south edge of the EB lane on Farmington Road at the following locations:

- Lt. Sta. 32+75 to sta. 45+00.
- Place pavement marking tape type III, 4" at the following locations:
 - Lt. sta. 33+70 to sta. 34+00, (4" solid white taper)
 - Lt. Sta. 34+00 to sta. 43+00, offset 5' from existing south edge of pavement on Farmington Road. (4" solid white)
 - Lt. sta. 43+00 to sta. 44+60, (4" solid white taper)

TRAFFIC

Farmington Road

Close the EB lane and shift EB traffic to center lane. Separate and define the opposing traffic lanes as shown in the typical section on this sheet. Traffic control shall conform to TC&P Standard 701502, except as noted or shown in the plan details and Special Provisions.

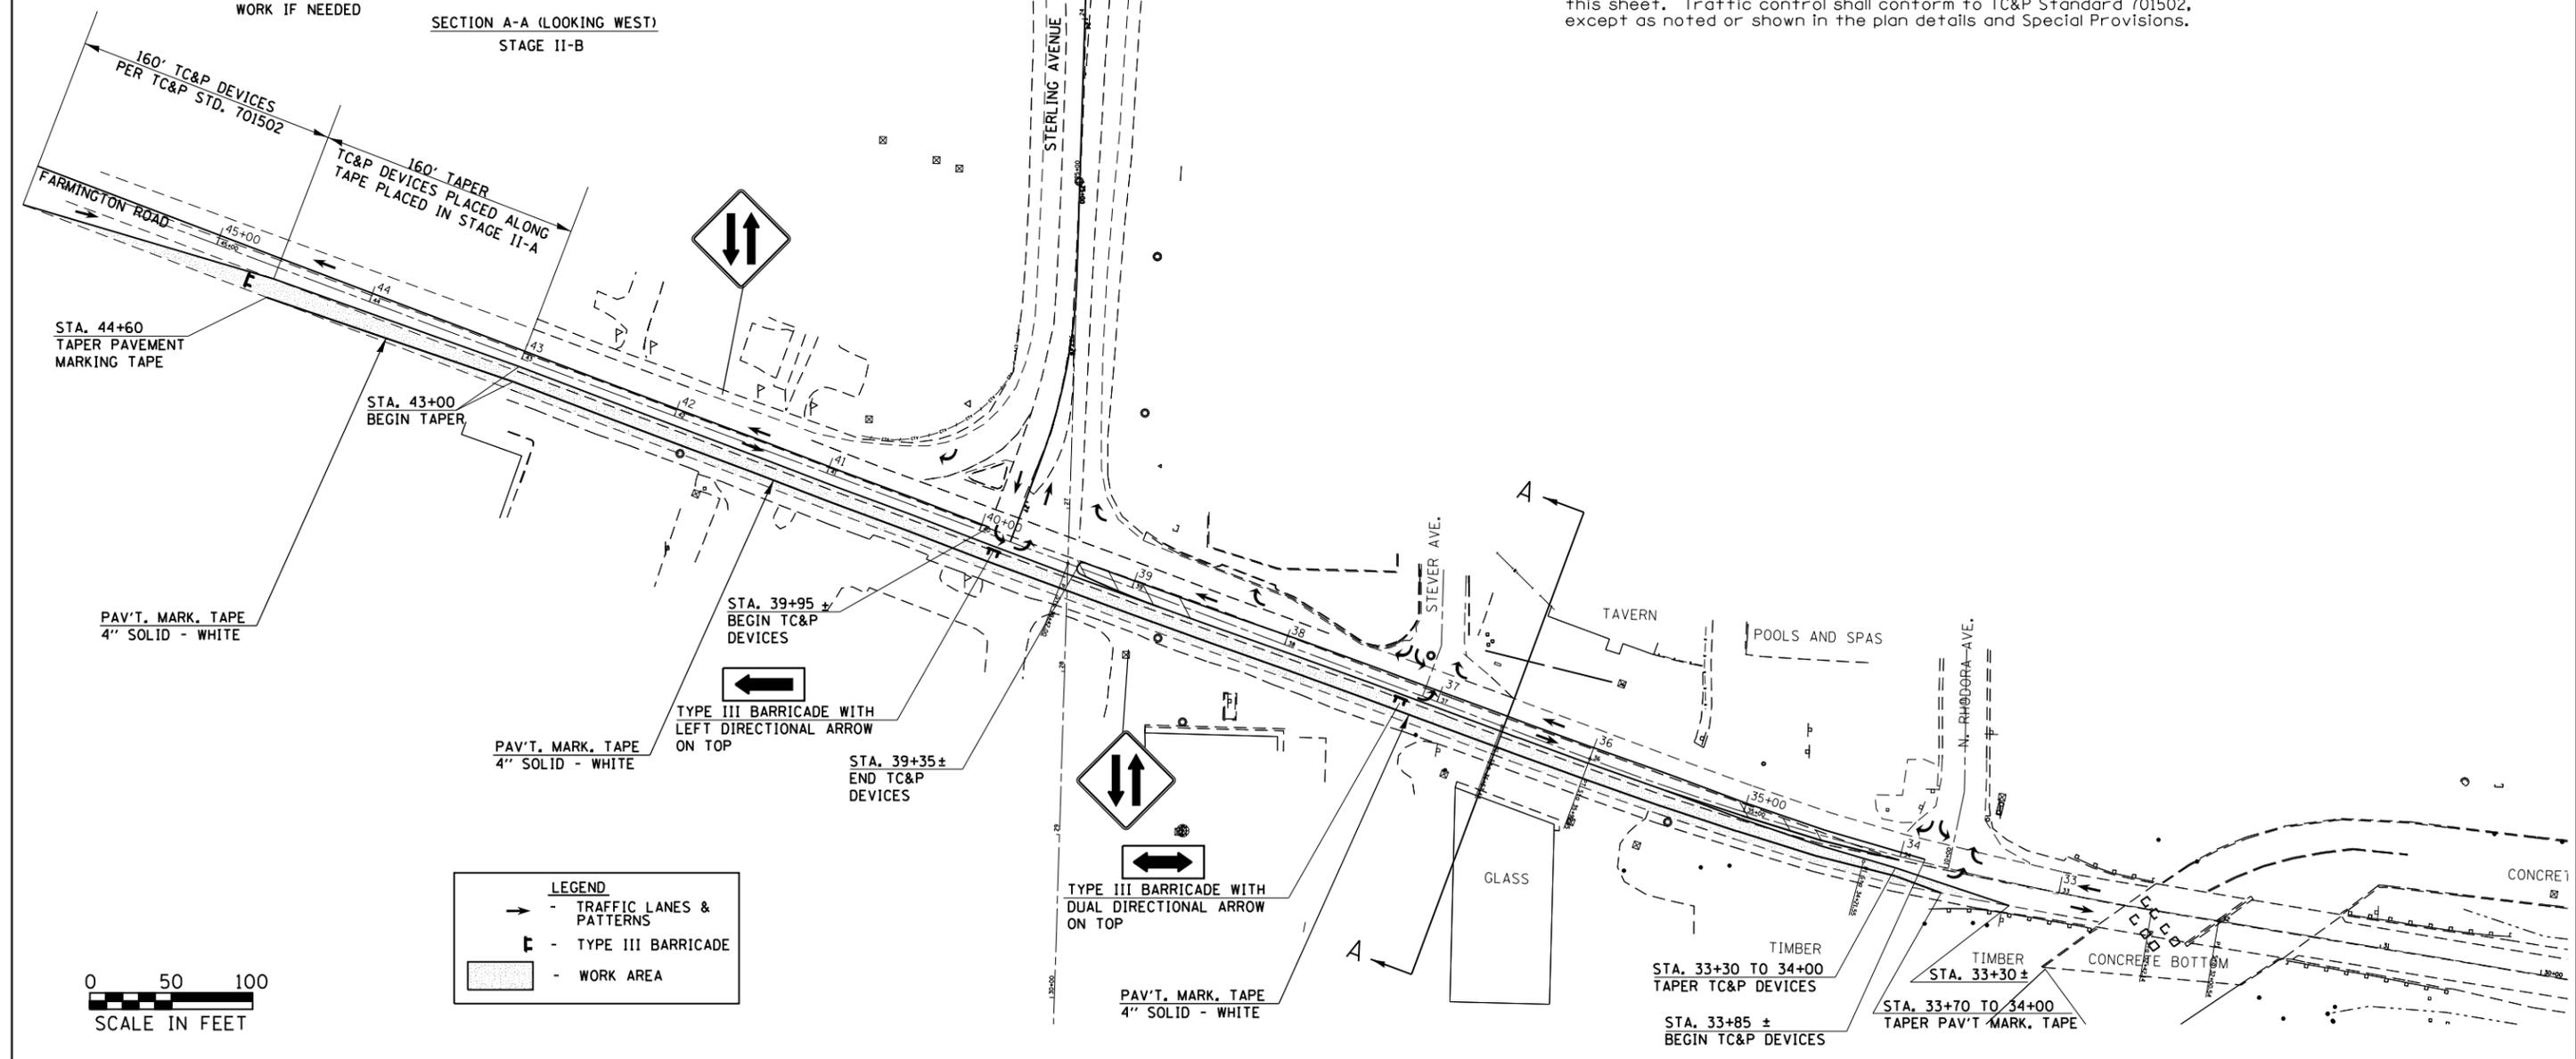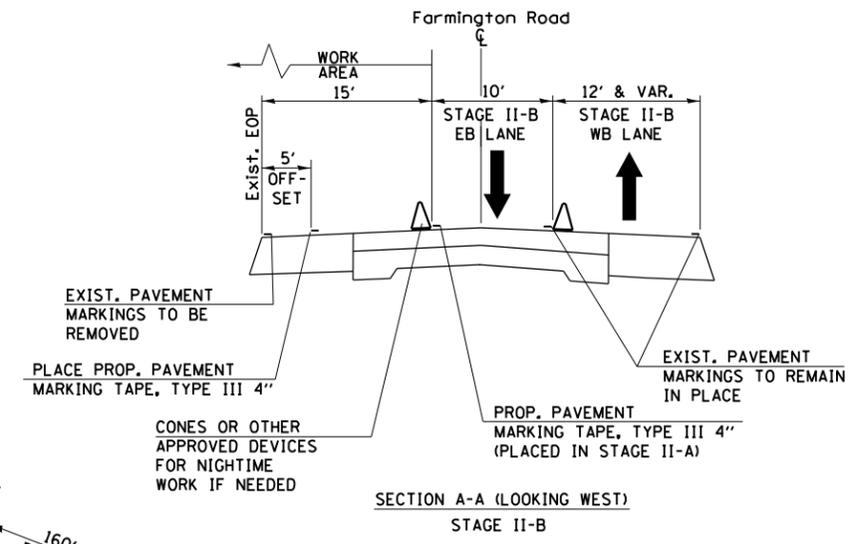

FILE NAME =	USER NAME = aubreys	DESIGNED -	REVISED -	STATE OF ILLINOIS DEPARTMENT OF TRANSPORTATION	TRAFFIC CONTROL PLAN - STAGE II-B	F.A.U. RTE.	SECTION	COUNTY	TOTAL SHEETS	SHEET NO.	
Default	Default	DRAWN -	REVISED -			6658	ION	PEORIA	120	30	
		CHECKED -	REVISED -			CONTRACT NO. 68A70					
		DATE -	REVISED -			ILLINOIS FED. AID PROJECT					