

SEQUENCE OF OPERATIONS

STAGE IV

NOTE: DAYTIME. Peak hour restrictions as described in the Special Provision entitled "Working Restrictions & Staging Notes" do not apply.

PURPOSE

Stage IV is designed to accommodate removal of the island in the NW quadrant of Sterling Ave. and the replacement with concrete base course.

CONSTRUCTION

- Remove existing island
- Replace with a high early strength PCC Base Course, type PP-2 material.
- Remove existing pavement markings at locations shown on the detail in preparation for future stages.
- Refresh remaining pavement markings, using tape, at existing locations around island prior to removing traffic control.
- Place stop bar within the closure as shown in the island detail for future stages prior to removing traffic control.

TRAFFIC

Farmington Road

Farmington Road shall remain open to normal traffic movement with possible variations in patterns during this stage.

Sterling Avenue

Close right turn lane of SB Sterling Avenue. Traffic control shall conform to TC&P Standard 701701, except as noted or shown in the plan details and Special Provisions. Traffic shall be channelized with approved devices to remain in place for nighttime closure, during non-working hours. No pavement marking tape shall be required, except at locations of stop bars.

The left turn lane traffic on SB Sterling Avenue shall be required to drive on the existing, flush concrete median during this stage.


Side Roads

Stever Avenue and Rhodora Avenue shall remain open to normal traffic movement with possible variations in patterns during this stage.

XXXXXXXXXX = PAVEMENT MARKING REMOVAL (REMOVE EXIST. PAVEMENT MARKINGS IN PREPARATION FOR FUTURE STAGES = 200')

STOP BAR SEE STAGE V FOR LOCATION

* MAY NEED TO ADJUST TC&P DEVICES ON THIS END TO ACCOMMODATE SEMI-TRACTOR TRAILER TURNING RADIUS

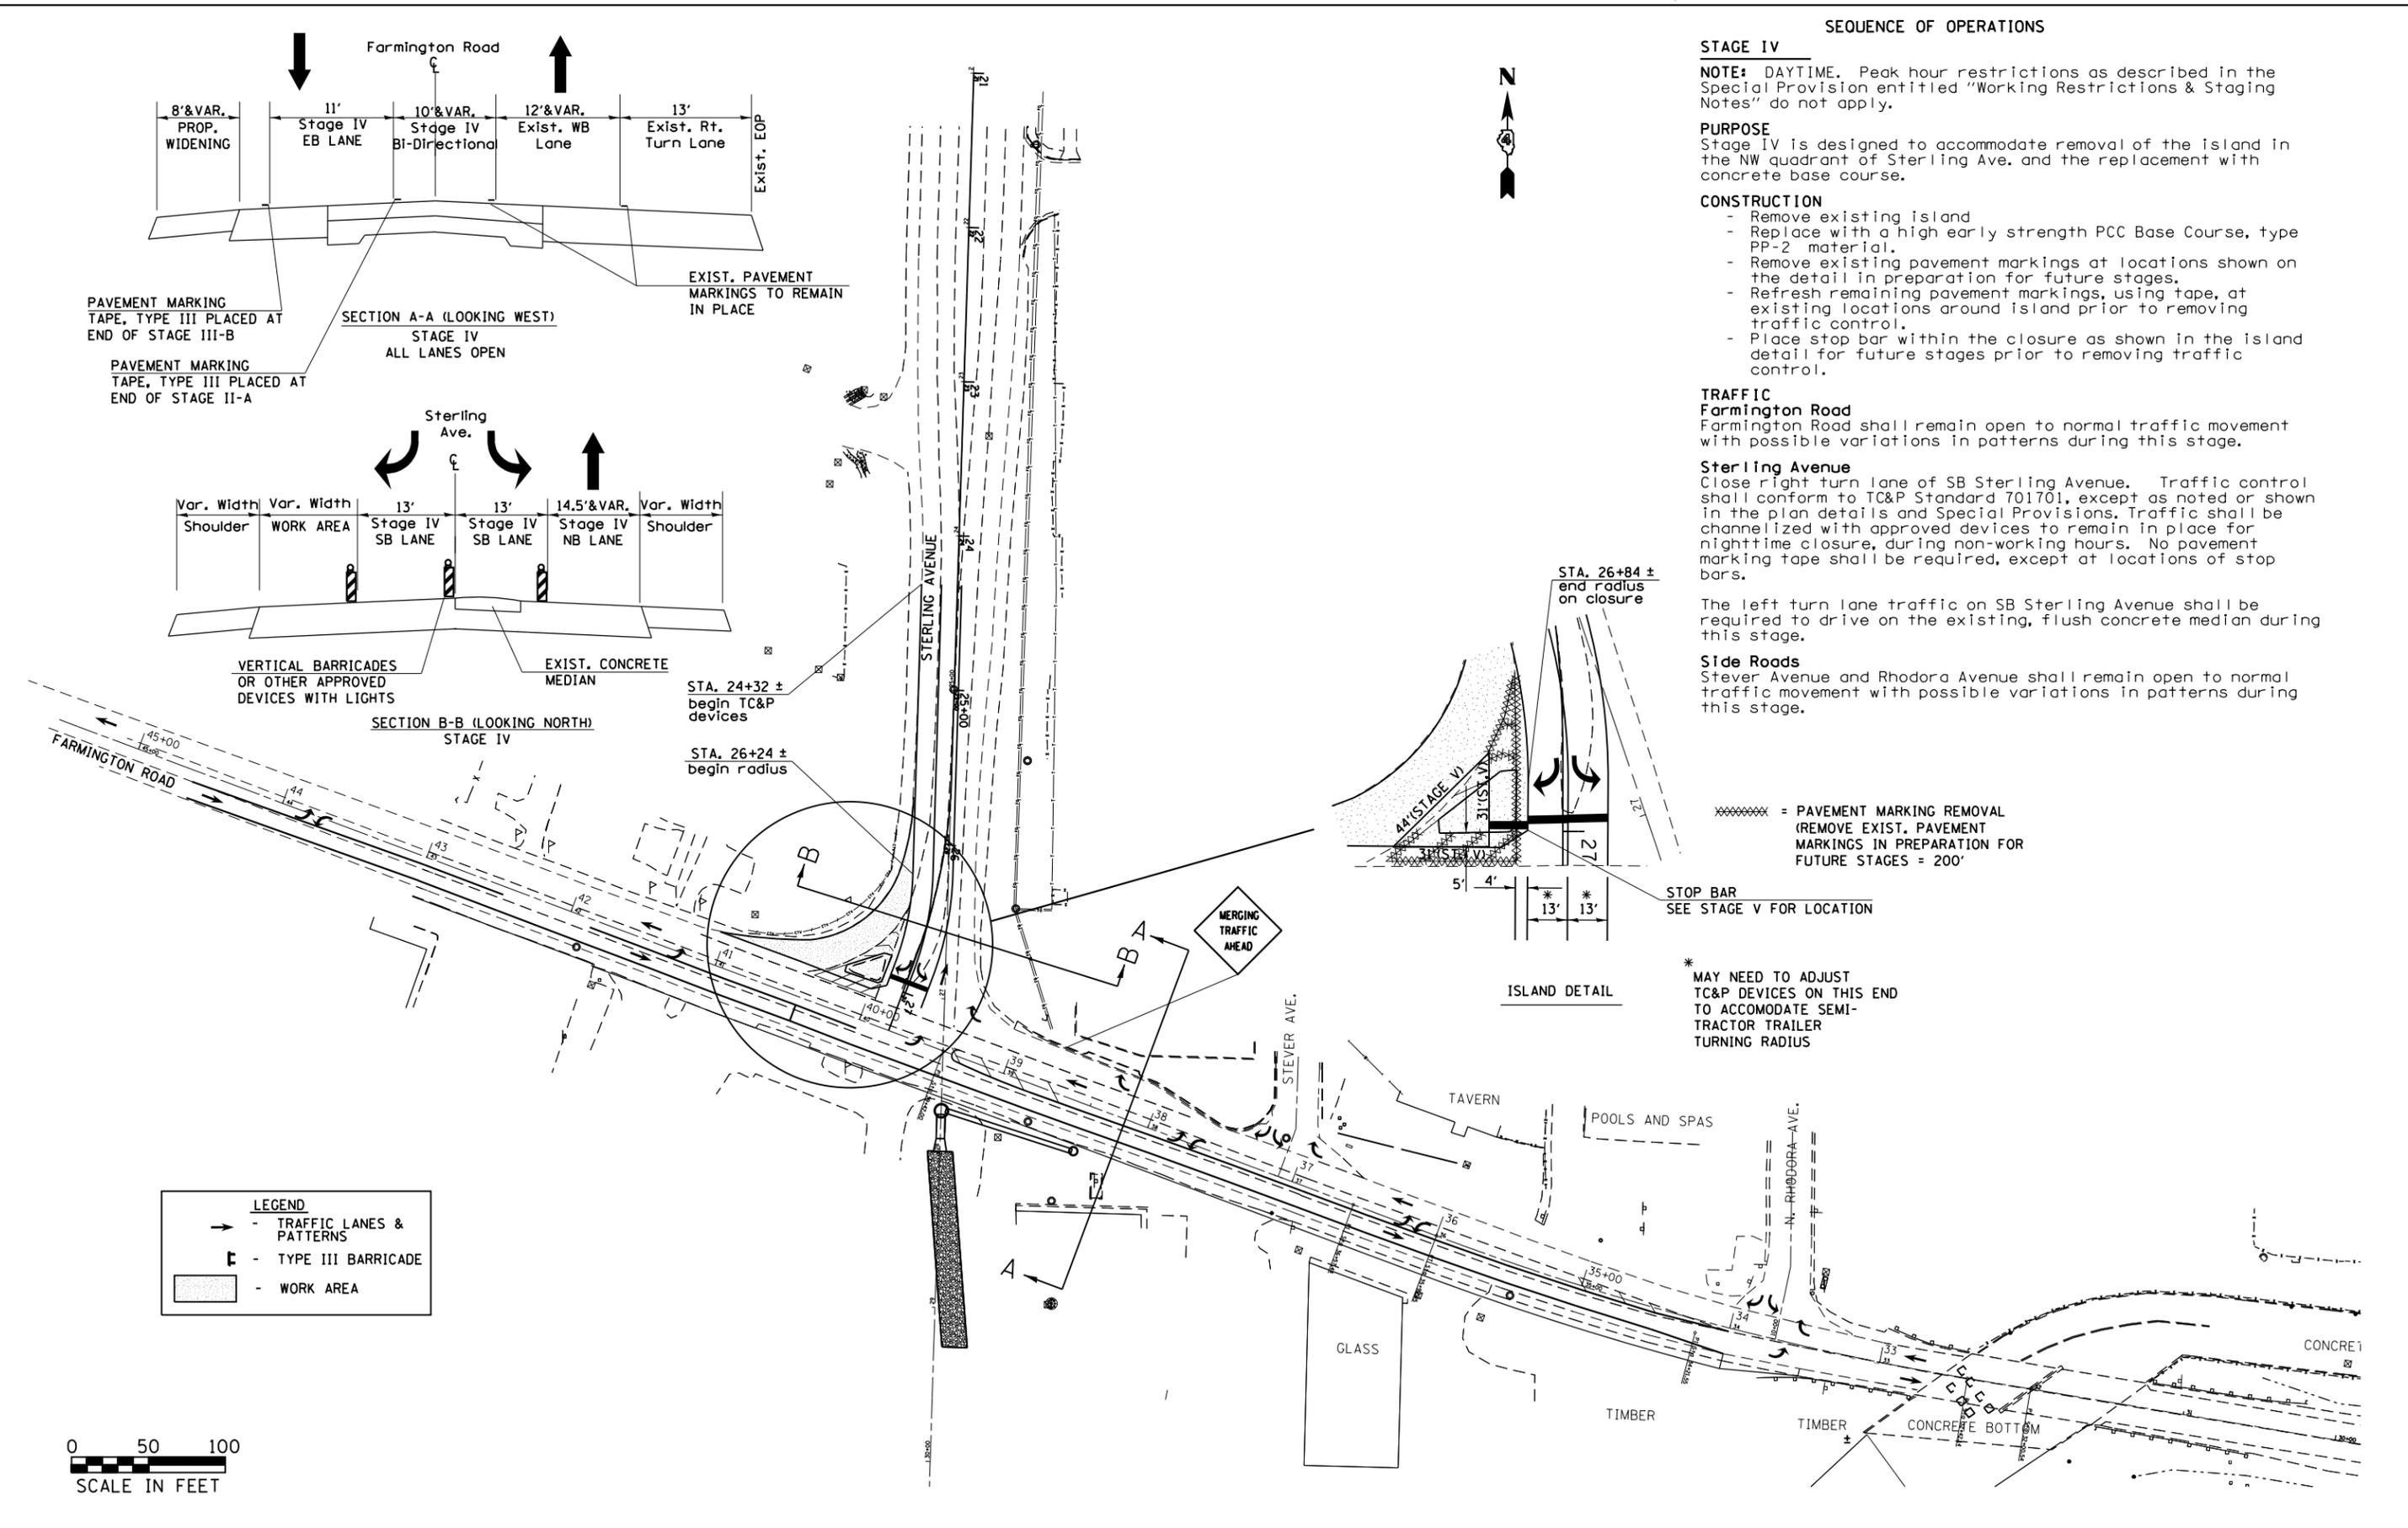

LEGEND

- - TRAFFIC LANES & PATTERNS
- ⌄ - TYPE III BARRICADE
- ▭ - WORK AREA

FILE NAME =	USER NAME = aubreys	DESIGNED -	REVISED -	STATE OF ILLINOIS DEPARTMENT OF TRANSPORTATION	TRAFFIC CONTROL PLAN - STAGE IV		F.A.U. RTE.	SECTION	COUNTY	TOTAL SHEETS	SHEET NO.
Default	ct:\pw\work\p1dot\aubreys\d0318675\046870-staging.dgn	DRAWN -	REVISED -				6658	10N	PEORIA	120	33
	PLOT SCALE = 100.0000' / 1".	CHECKED -	REVISED -				CONTRACT NO. 68A70				
	PLOT DATE = 10/17/2013	DATE -	REVISED -				ILLINOIS FED. AID PROJECT				