

SEQUENCE OF OPERATIONS

STAGE VI

NOTE: See the Special Provision entitled "Working Restrictions & Staging Notes", (No. 16) for work hour restrictions on this stage.

PURPOSE

Stage VI is designed for installation of the cross road culvert and manhole at sta. 38+40 on the north side of Farmington Road.

CONSTRUCTION

- Work area for this stage is defined from sta. 38+00 to 39+36.
- Install manhole at rt. sta. 38+40.
- Remove pavement and install pipe culvert beginning at the centerline of Farmington Road and install in the direction of the manhole.
- Replace pavement with a Class D Patch with PP-2 material requirements.

TRAFFIC

Sterling Avenue




In an effort to keep traffic centralized within the intersection and within temporary signal installations for controlled turns, close the right turn lane of SB Sterling Avenue and shift both the left and right turn lanes to the east as shown on this sheet. Traffic control shall conform to TC&P Standard 701701, except as noted or shown in the plan details and Special Provisions. Traffic shall be channelized with approved devices to remain in place for nighttime closure, during non-working hours. No pavement marking tape shall be required, except at locations of stop bars.

Farmington Road

Shift the EB traffic lane of Farmington Road onto new widening on the south side of pavement. Close both the WB lane and center bi-directional turn lane and shift the WB traffic lane to EB lane previously defined by pavement marking tape. One lane in each direction shall remain open. Traffic control shall conform to TC&P Standard 701502, except as noted or shown in the plan details and Special Provisions. Traffic shall be channelized with approved devices to remain in place for nighttime closure, during non-working hours.

Side roads

Rhodora Avenue shall remain open to normal traffic movement with possible variations in patterns during this stage. Close the SB lane of Stever Avenue and gap traffic control devices to allow NB traffic only.

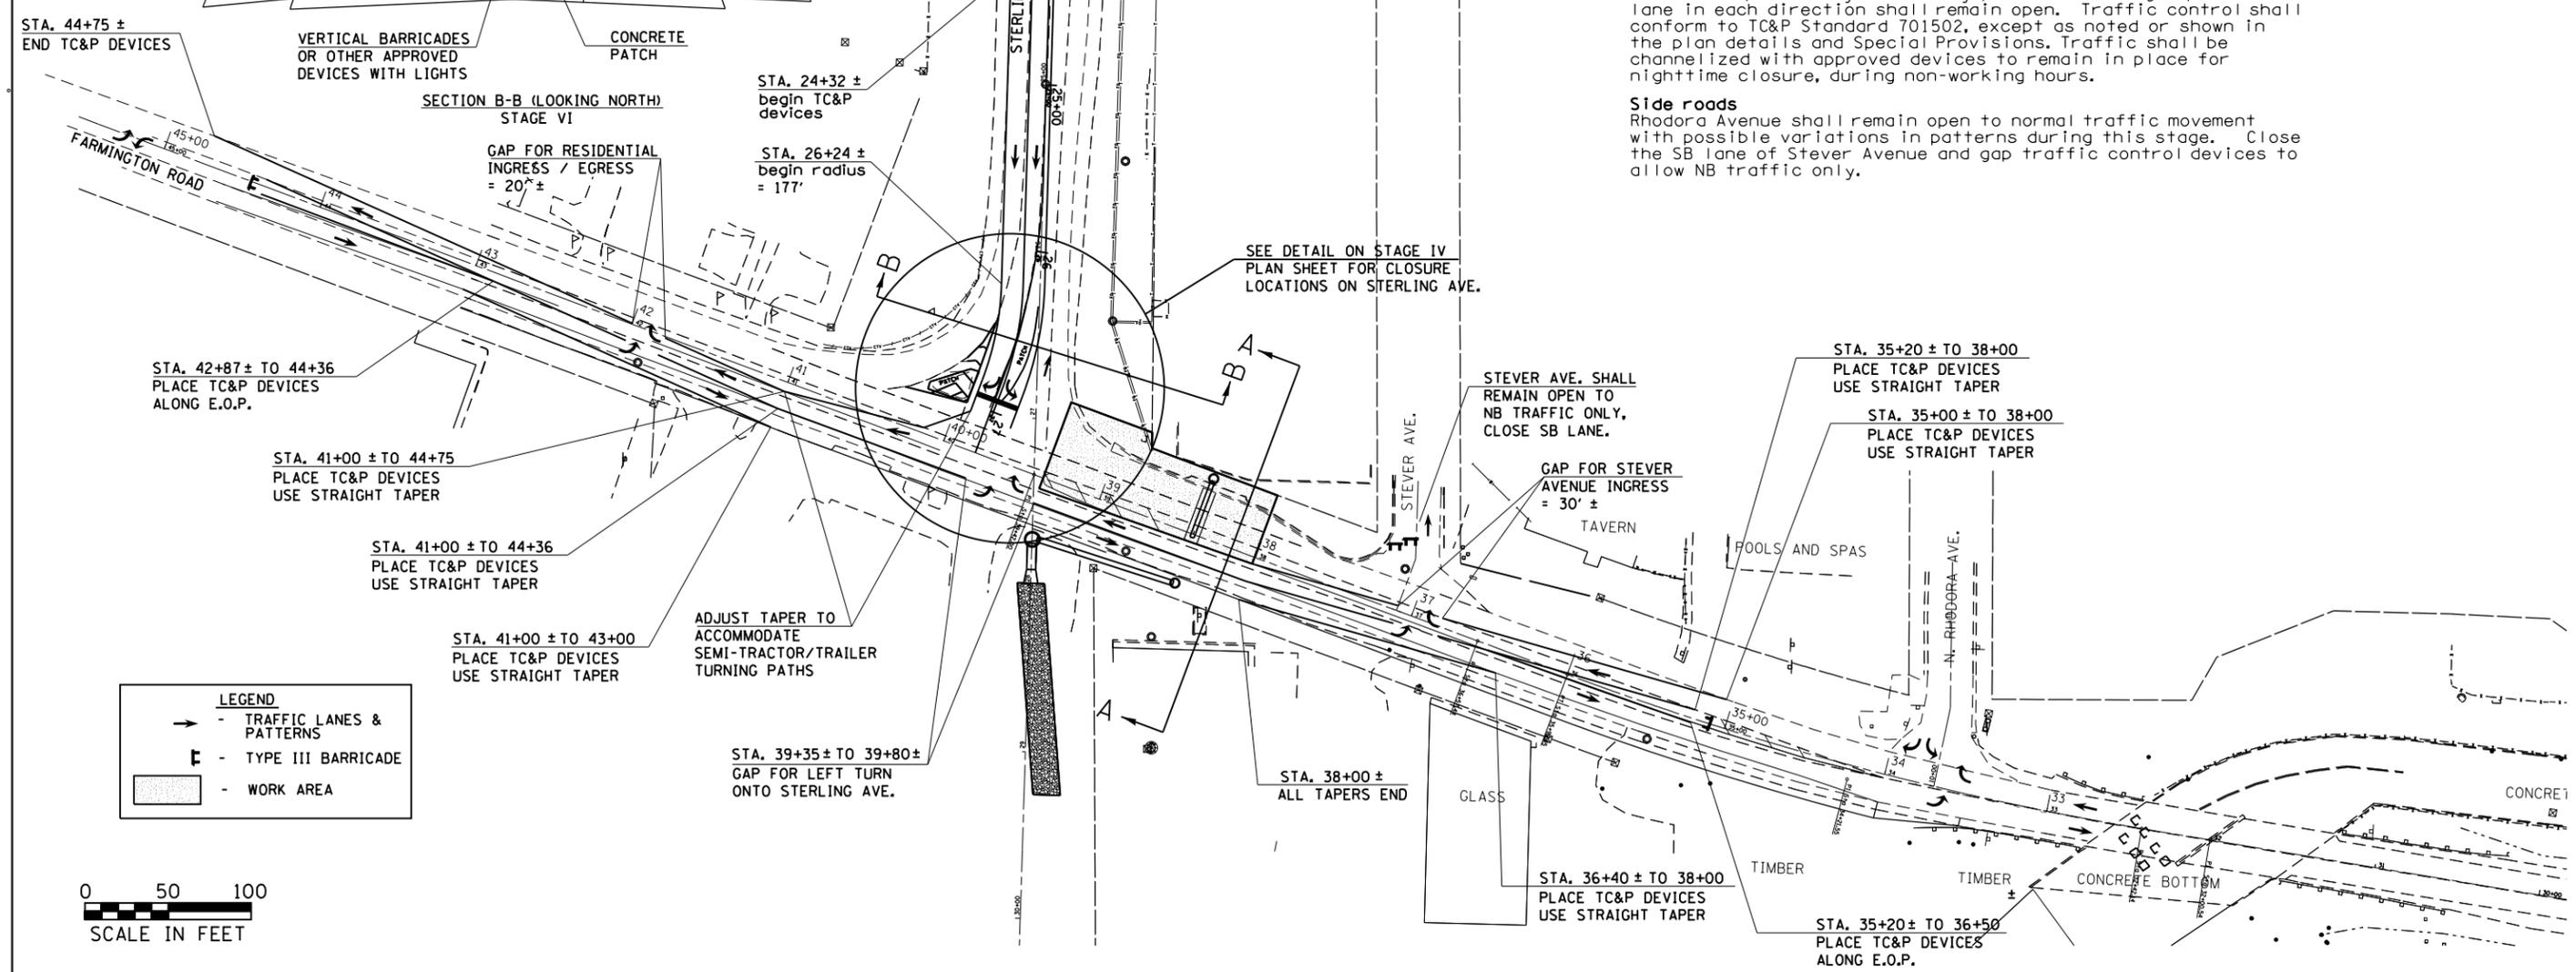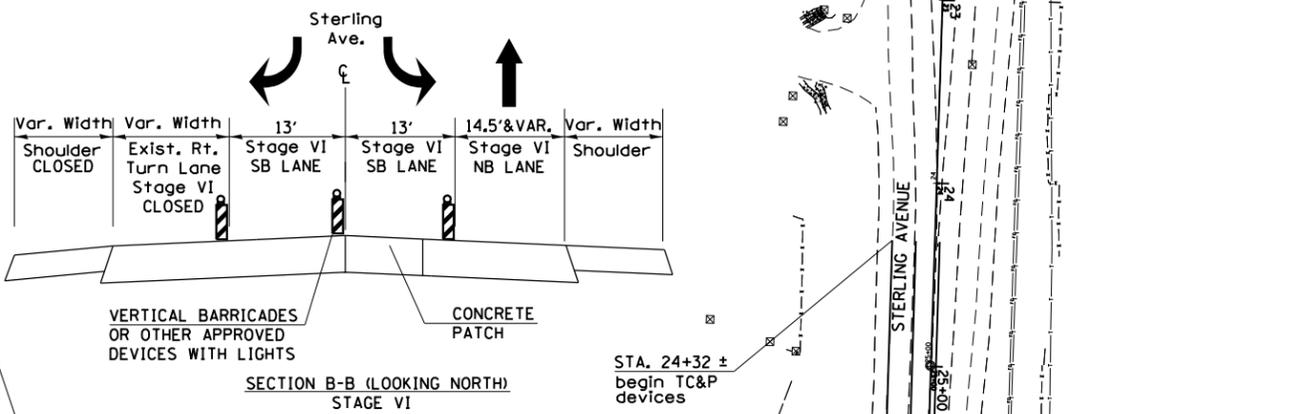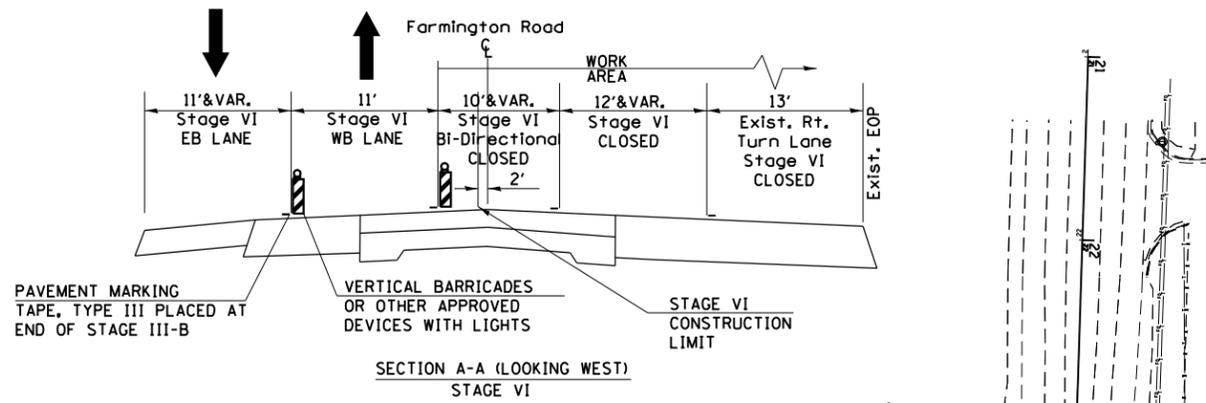

LEGEND	
	TRAFFIC LANES & PATTERNS
	TYPE III BARRICADE
	WORK AREA

FILE NAME =	USER NAME = aubreys	DESIGNED -	REVISED -	STATE OF ILLINOIS DEPARTMENT OF TRANSPORTATION	TRAFFIC CONTROL PLAN - STAGE VI		F.A.U. RTE.	SECTION	COUNTY	TOTAL SHEETS	SHEET NO.
Default	Plot DATE = 10/17/2013	DRAWN -	REVISED -				6658	10N	PEORIA	120	35
		CHECKED -	REVISED -				CONTRACT NO. 68A70				
		DATE -	REVISED -				ILLINOIS FED. AID PROJECT				