



**SEQUENCE OF OPERATIONS**


**STAGE X**

**NOTE:** The contractor shall maintain one lane of traffic in each direction at all times.

**PURPOSE**

This is a generalized stage to complete all remaining work including but not limited to:

- Work zone pavement marking removal
- HMA surface removal
- HMA surface placement
- Remaining traffic signal work
- Placement of permanent pavement markings

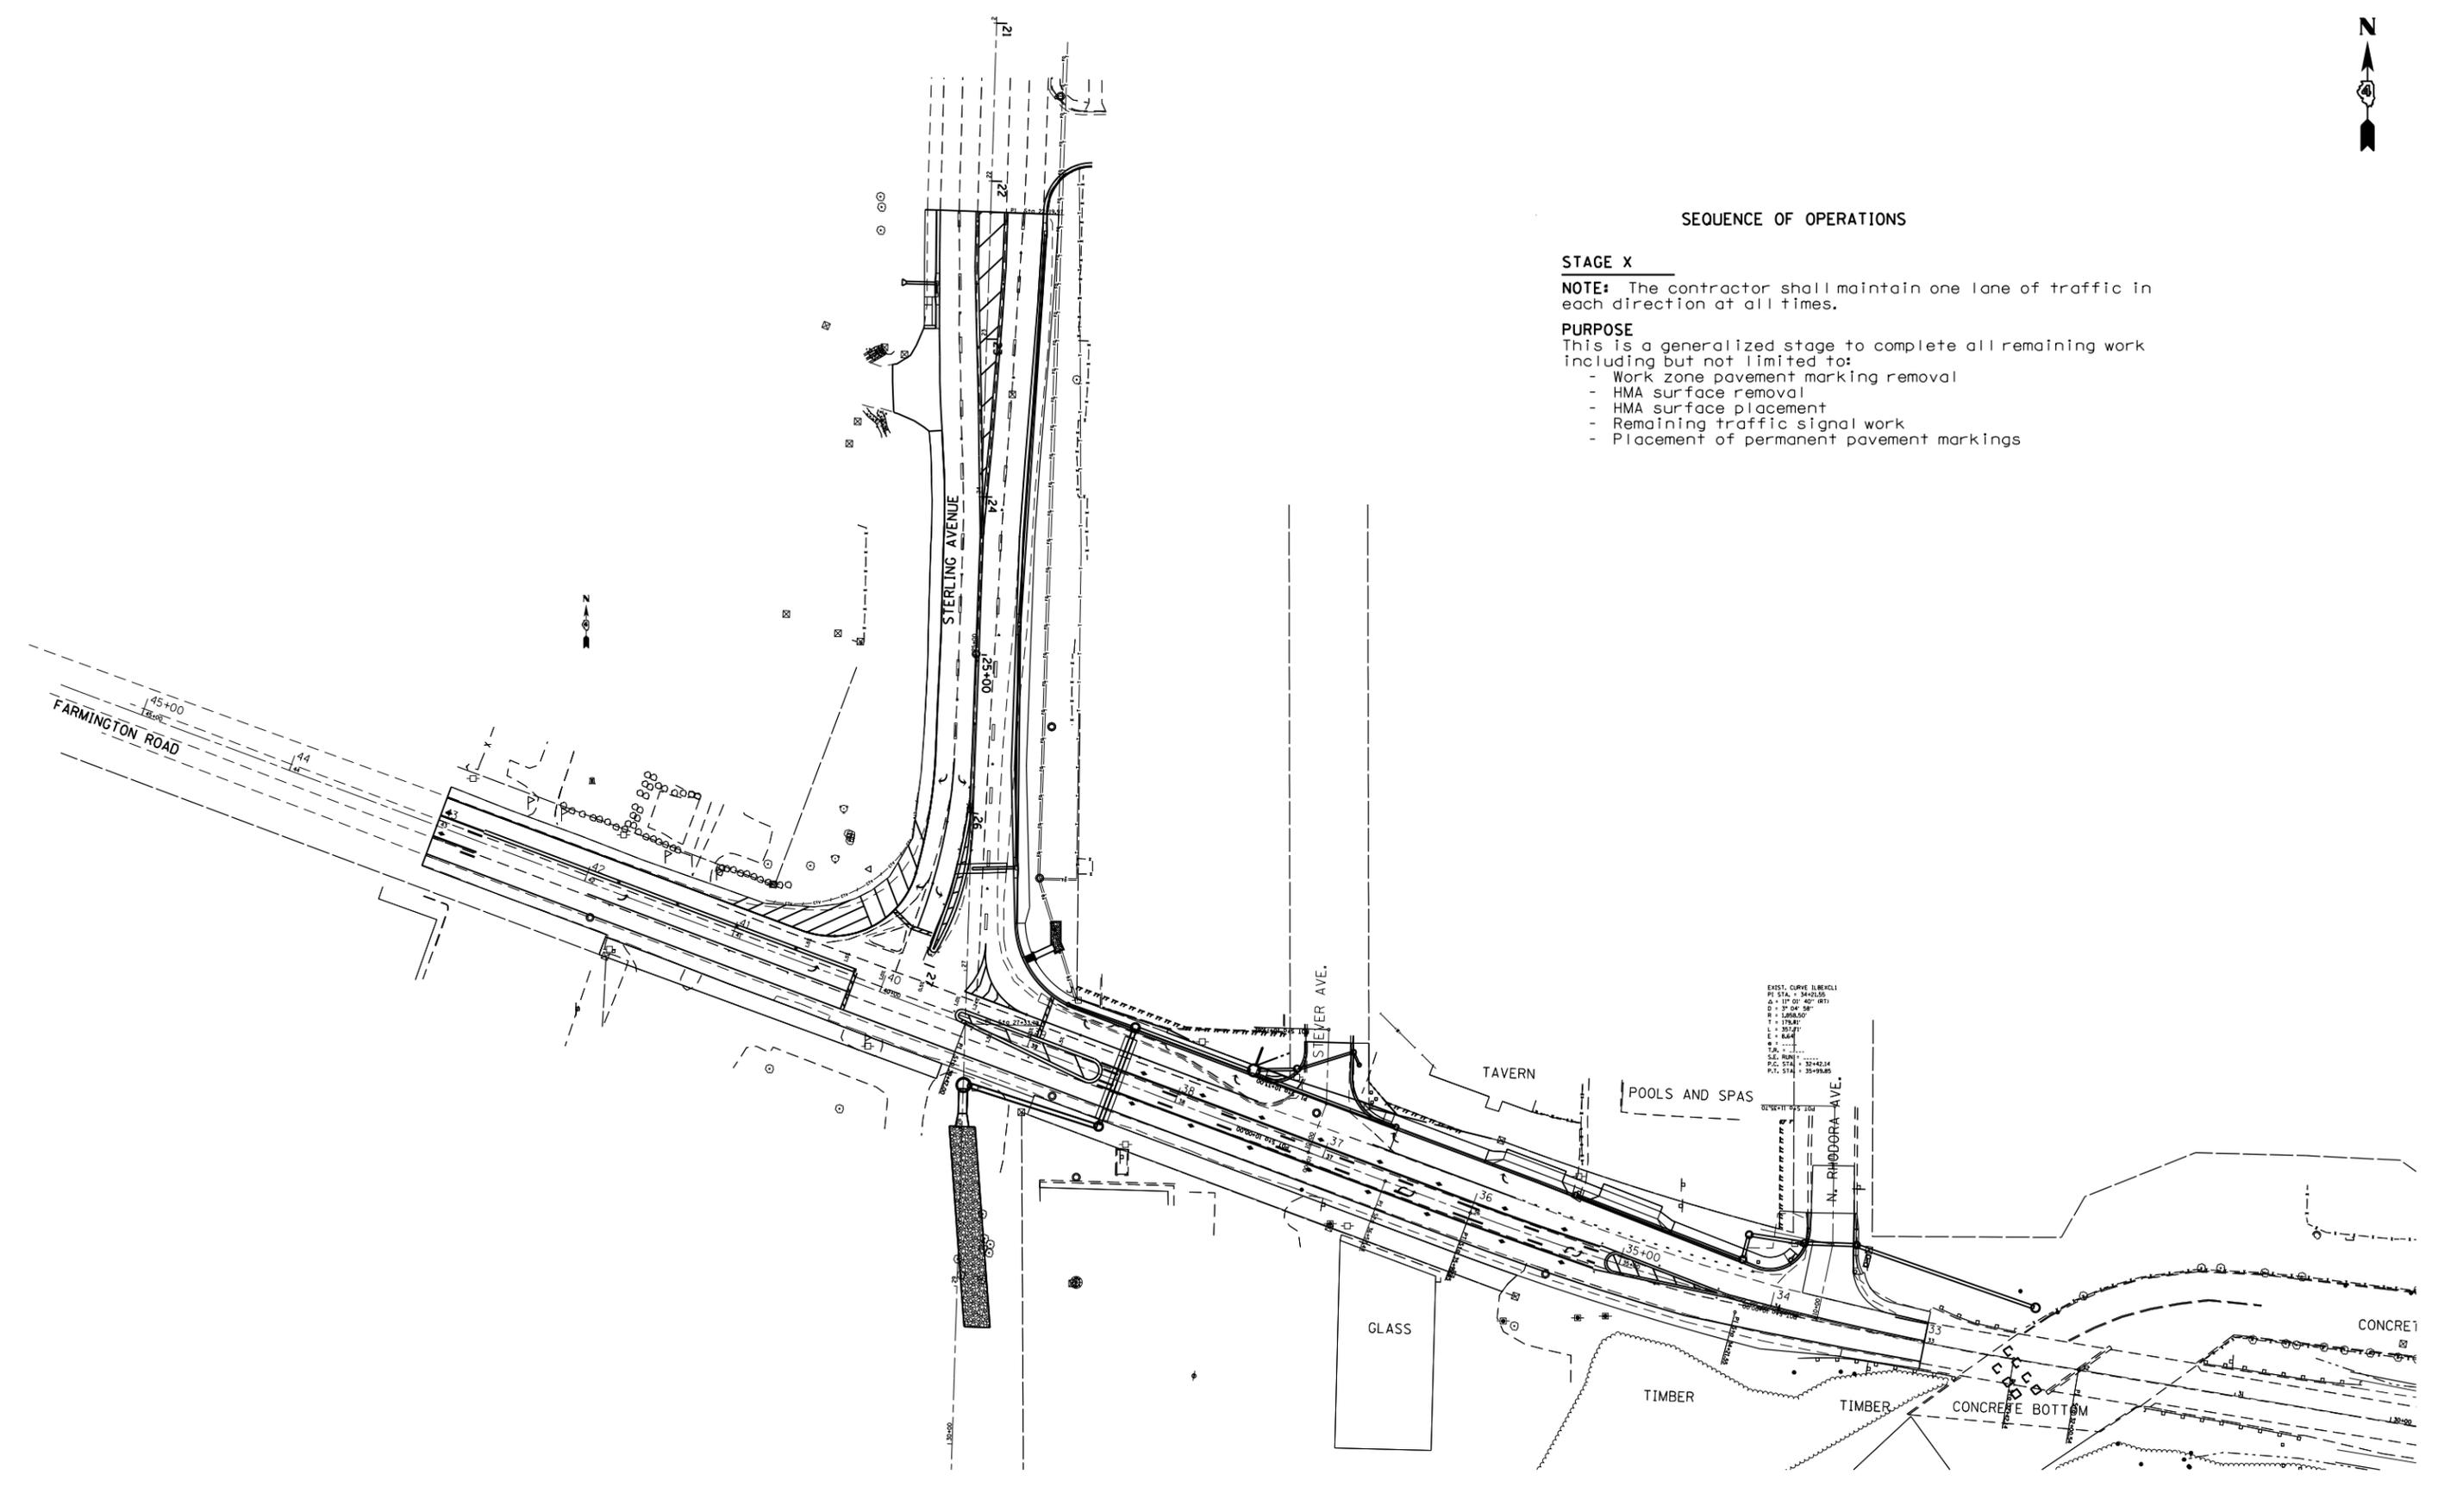

FILE NAME =	USER NAME = aubreys	DESIGNED -	REVISED -
ct:\pw\work\p\dot\aubreys\d0318675\046870-staging.dgn		DRAWN -	REVISED -
Default	PLOT SCALE = 100.0000' / in.	CHECKED -	REVISED -
	PLOT DATE = 10/17/2013	DATE -	REVISED -

**STATE OF ILLINOIS  
DEPARTMENT OF TRANSPORTATION**

**TRAFFIC CONTROL PLAN - STAGE X**

SCALE: SHEET 11 OF 11 SHEETS STA. TO STA.

F.A.U. RTE.	SECTION	COUNTY	TOTAL SHEETS	SHEET NO.
6658	10N	PEORIA	120	39
CONTRACT NO. 68A70				
ILLINOIS FED. AID PROJECT				