



PLAN	SURVEYED	BY	DATE
	PLOTTED		
	CHECKED		
	ALIGNED		
	FILED		
	NO.		

PROFILE	SURVEYED	BY	DATE
	PLOTTED		
	CHECKED		
	GRADES		
	STRUCTURE		
	NOTATIONS		
	CHKD		
	NO.		

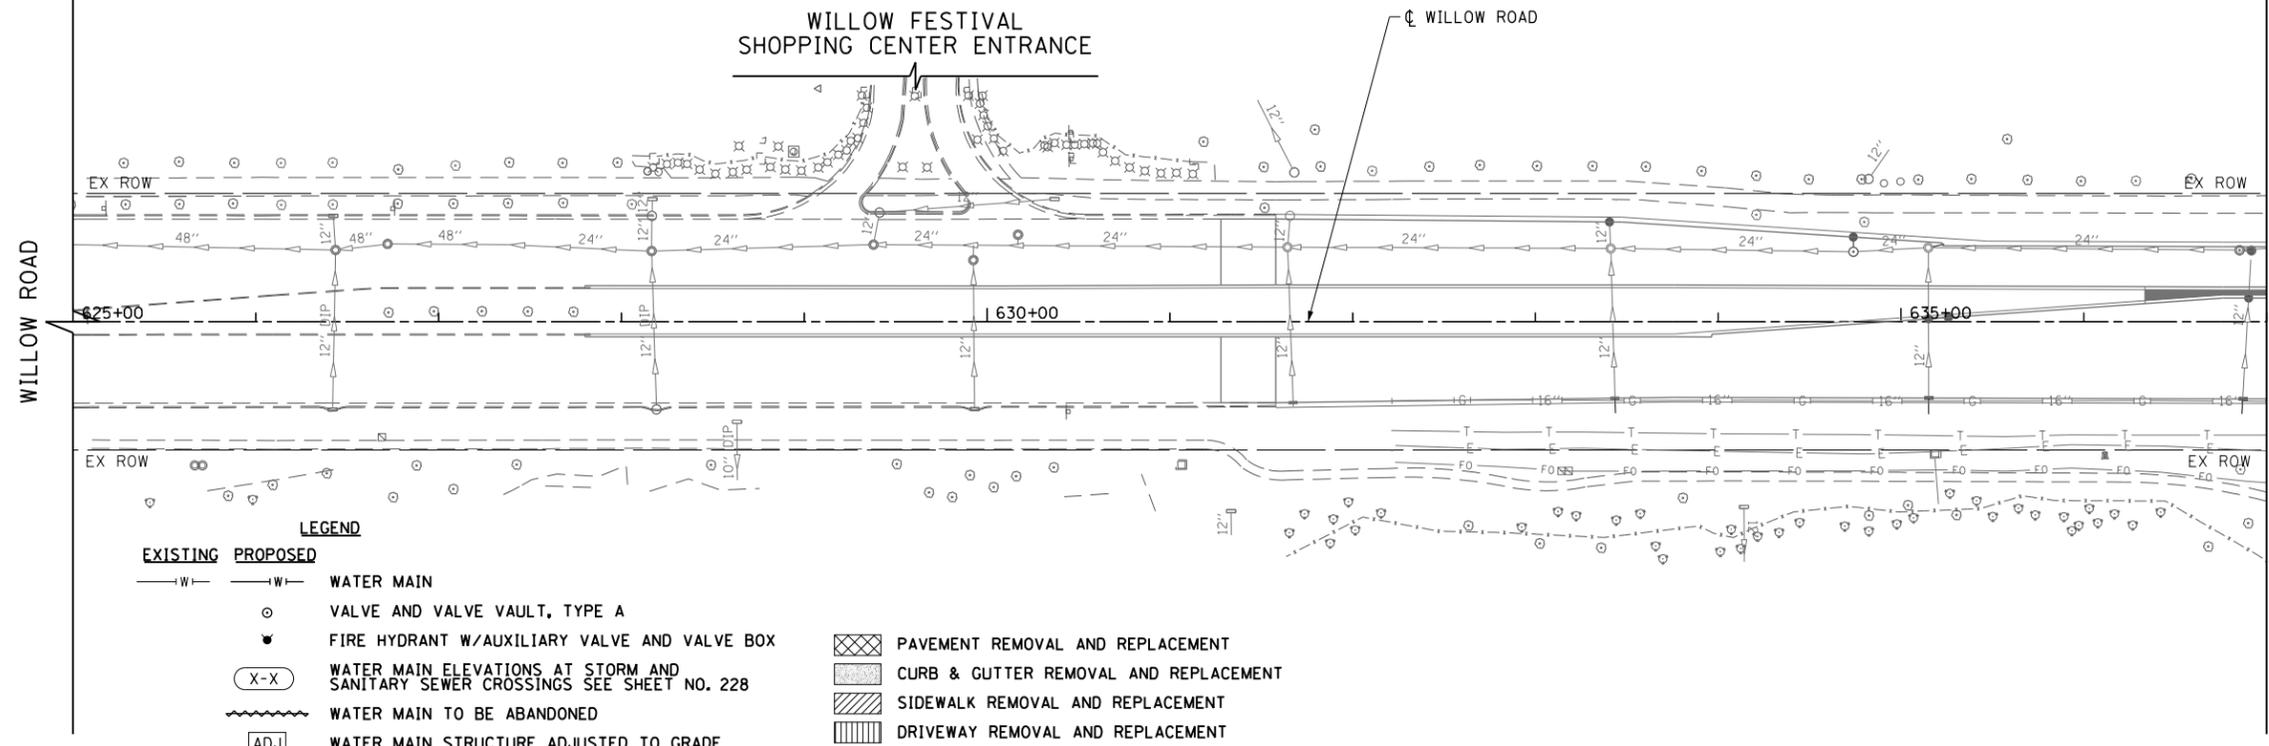

MATCH LINE STATION 637+00
SEE SHEET NO. 217

- NOTES:
1. THE COST OF ALL FITTINGS AND LABOR REQUIRED TO CONNECT EXISTING WATER SERVICES TO PROPOSED CURB STOPS SHALL BE INCLUDED IN THE UNIT PRICE BID FOR THE CURB STOP AND BUFFALO BOX.
 2. ACCESS VIA DRIVEWAYS SHALL BE MAINTAINED BEFORE 9 AM AND AFTER 4 PM DAILY.
 3. THE CONTRACTOR SHALL VERIFY THE DEPTH OF ALL EXISTING UTILITIES BEFORE INSTALLING PROPOSED WATER MAINS (TYPICAL).
 4. RESTORATION SHALL BE LAID OUT BY THE FIELD ENGINEER PER PROJECT SPECIFICATIONS.
 5. ALL RETIRED MAINS WITHIN PROJECT LIMITS SHALL BE FILLED WITH CONTROLLED LOW-STRENGTH MATERIAL (MIX 1) IN CONFORMANCE WITH SECTION 593 OF THE STANDARD SPECIFICATIONS.
 6. THE CONTRACTOR SHALL COORDINATE WITH THE VILLAGE OF NORTHFIELD ON PERMISSIBLE TIMES FOR SHUTDOWN PROCEDURES AND SERVICE INTERRUPTIONS. A MINIMUM OF 48 HOURS NOTICE IS REQUIRED FOR ALL SERVICE INTERRUPTIONS.
 7. ALL REMOVED VALVES AND HYDRANTS SHALL BE PROVIDED TO THE VILLAGE OF NORTHFIELD AFTER REMOVAL. THIS WORK WILL NOT BE PAID FOR SEPARATELY, BUT SHALL BE INCLUDED IN THE UNIT BID PRICES OF THE CONTRACT.
 8. ALL VALVES SHALL BE OPERATED BY NFPW PERSONNEL ONLY.

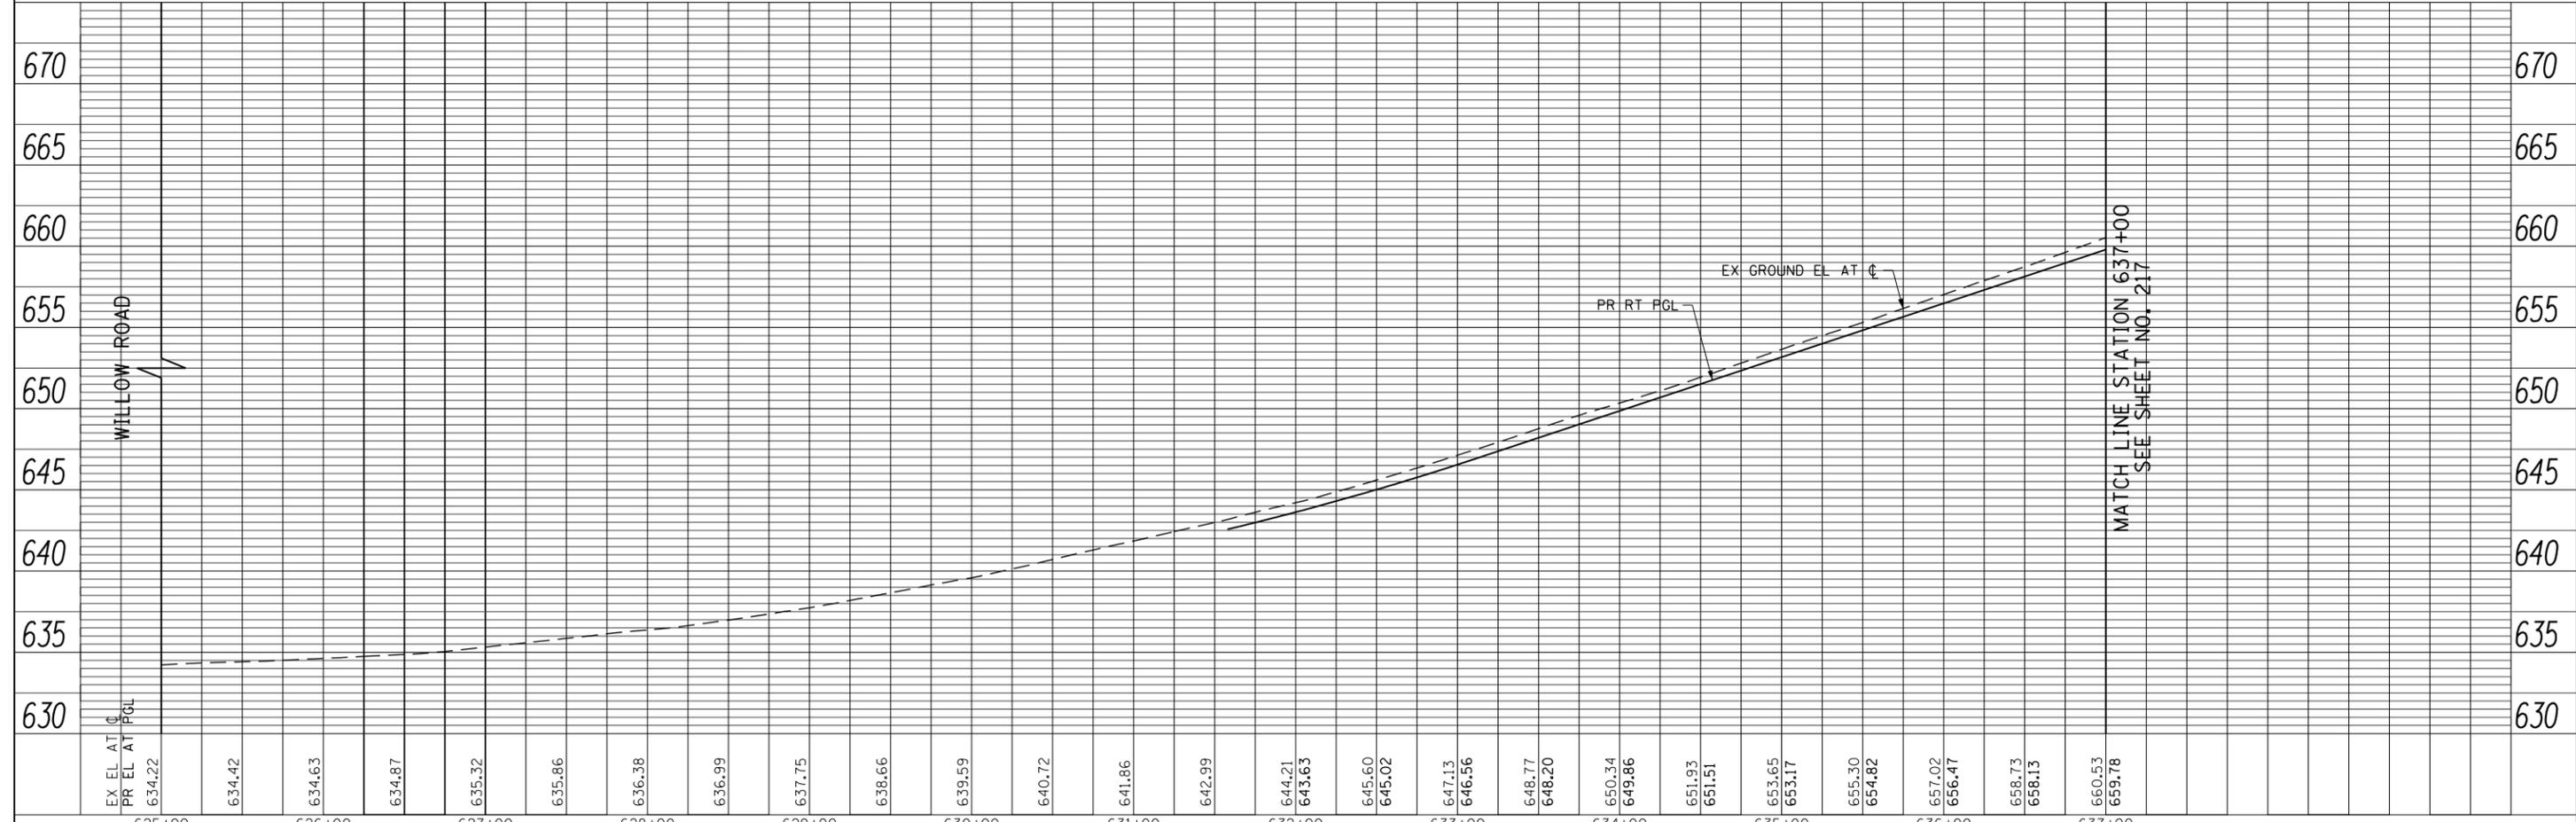

MATCH LINE STATION 637+00
SEE SHEET NO. 217

FILE NAME =	USER NAME = BAW:ort	DESIGNED - JLV	REVISED -	STATE OF ILLINOIS DEPARTMENT OF TRANSPORTATION	WILLOW ROAD WATER MAIN PLAN AND PROFILE	F.A.P. RFE.	SECTION	COUNTY	TOTAL SHEETS	SHEET NO.
g:\ch11\0158\road\Sheets\0160T35-SHT-WM-01.dgn	DRAWN - KAL	REVISED -	305			(1920,01,1518,2022&1922,4BR	COOK	919	216	
PLOT SCALE = 100.000' / in.	CHECKED - RCB	REVISED -	CONTRACT NO. 60T35							
PLOT DATE = 11/1/2012	DATE - 10/31/2012	REVISED -	FED. ROAD DIST. NO. 1 ILLINOIS FED. AID PROJECT							
SCALE: HORIZ: 1"=50'		SHEET NO. 216 OF 919 SHEETS		STA. 625+00 TO STA. 637+00						