

F.A.I. RTE.	SECTION	COUNTY	TOTAL SHEETS	SHEET NO.
270	60-(1,2) L-1	MADISON	31	1

STATE OF ILLINOIS
DEPARTMENT OF TRANSPORTATION
DIVISION OF HIGHWAYS

**PROPOSED
HIGHWAY PLANS**

FAI ROUTE 270
SECTION 60-(1,2) L-1

MADISON COUNTY
HIGHWAY LIGHTING REHABILITATION
C-98-065-07


INDEX OF SHEETS

- 1 COVER SHEET
- 2 ELECTRICAL GENERAL NOTES
- 3 SUMMARY OF QUANTITIES
- 4 LEGEND AND NIGHTTIME LIGHTING INSPECTION DETAIL
- 5 VARIABLE MESSAGE BOARDS DISPLAY
- 6-11 HIGHWAY LIGHTING PLANS
- 12-14 CONDUITS ATTACHMENT DETAILS
- 15 RIVER BRIDGE WIRING DIAGRAM
- 16 CANAL BRIDGE WIRING DIAGRAM
- 17 RIVER BRIDGE CONTROL INSTALLATION
- 18 CANAL BRIDGE CONTROL INSTALLATION
- 19 POLE STANDARD
- 20 LIGHT POLE FOUNDATION STANDARD
- 21 LUMINAIRE PERFORMANCE TABLES
- 22-27 POLE FOUNDATION REPAIR PLANS-RIVER BRIDGE (SN# 060-0035)
- 28-31 POLE FOUNDATION REPAIR PLANS-CANAL BRIDGE (SN# 060-0036 EB; 060-0037 WB)

STANDARD

- 701101-01
- 701106-01
- 701401-04
- 701411-04
- 701901
- 720001

MICROFILMED _____
REEL NUMBER _____
AWARDED _____
RESIDENT ENGINEER _____
AS BUILT CHANGES WERE MADE
ON THE FOLLOWING SHEETS


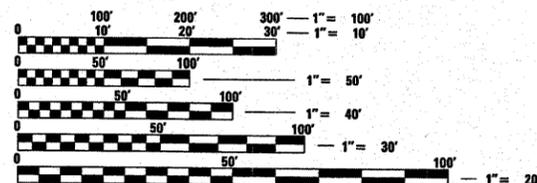


FULL SIZE PLANS HAVE BEEN PREPARED USING STANDARD ENGINEERING SCALES. REDUCED SIZED PLANS WILL NOT CONFORM TO STANDARD SCALES. IN MAKING MEASUREMENTS ON REDUCED PLANS, THE ABOVE SCALES MAY BE USED.


J.U.L.I.E.
JOINT UTILITY LOCATION INFORMATION FOR EXCAVATION
1-800-892-0123

CONTRACT NO. 76A88

PROJECT ENGINEER: PATTI LEBEAU (618) 346-3179
SQUAD LEADER: BHARAT PATEL (618) 346-3190

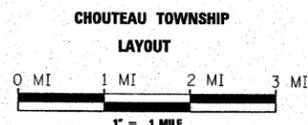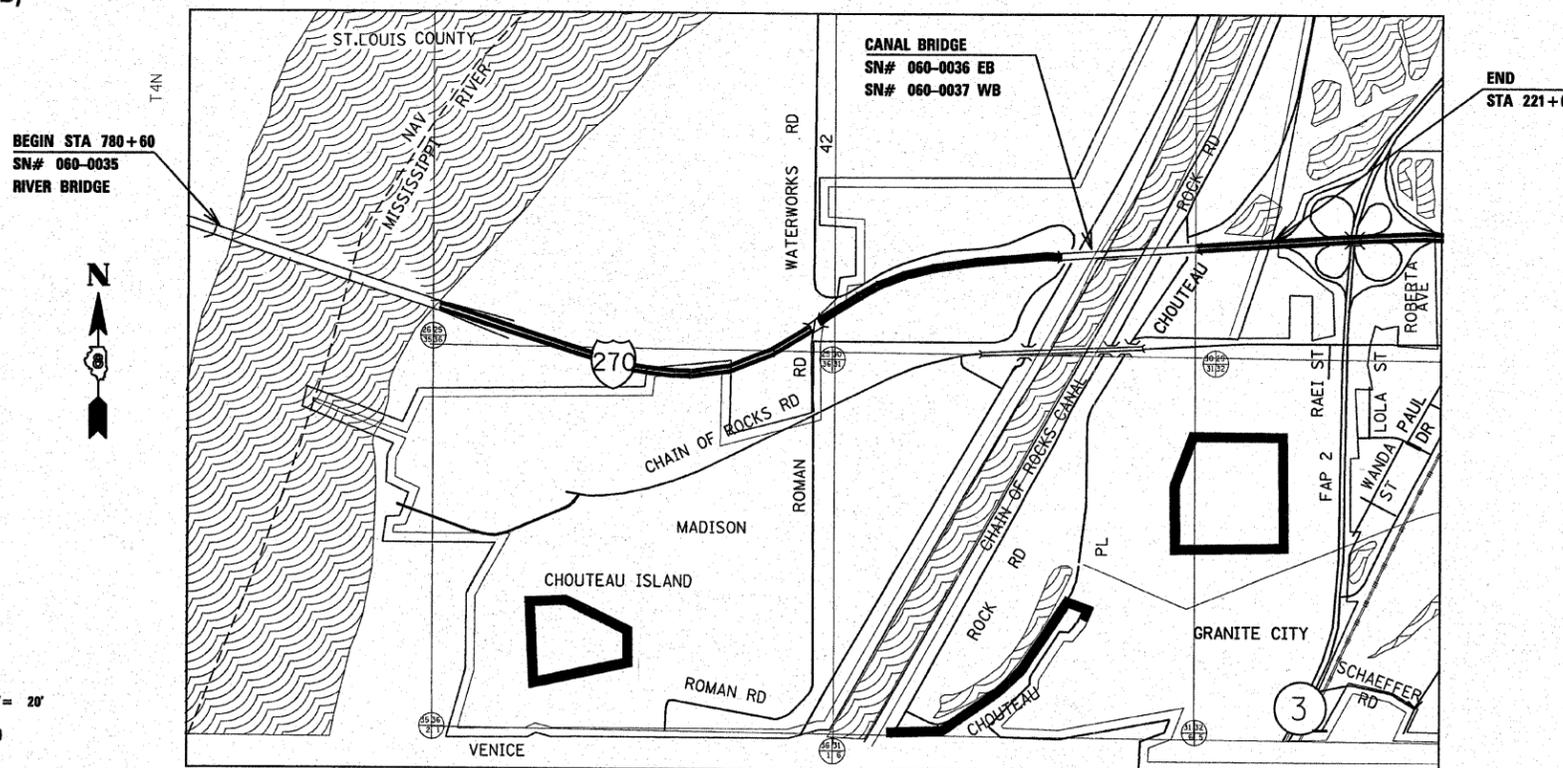

GROSS LENGTH 15,450.84 FT
NET LENGTH 15450.84 FT

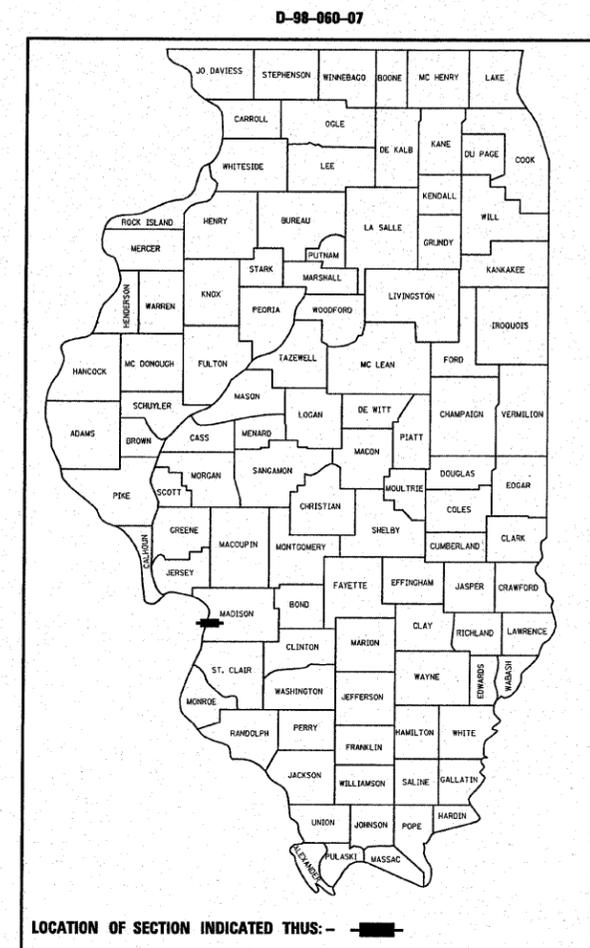

TRAFFIC DATA:
2007 ADT = 54,700 (ACTUAL)
2008 ADT = 55,200 (ESTIMATED)

STATE OF ILLINOIS
DEPARTMENT OF TRANSPORTATION
DIVISION OF HIGHWAYS

SUBMITTED December 14, 2007
Mary Jamie
DEPUTY DIRECTOR OF HIGHWAYS
REGION FIVE ENGINEER

February 1, 2008
Eric E. Harn
ENGINEER OF DESIGN AND ENVIRONMENT

February 1, 2008
Christine M. Reed
DIRECTOR, DIVISION OF HIGHWAYS

**PRINTED BY THE AUTHORITY
OF THE STATE OF ILLINOIS**