
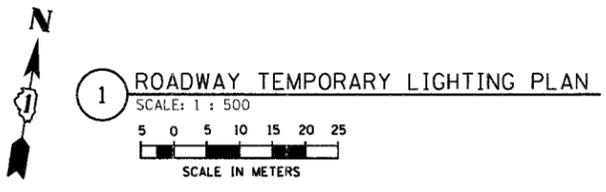


| | | | | |
|-----------------------|----------|------------------|--------------|-----------|
| F.A.P. RTE. | SECTION | COUNTY | TOTAL SHEETS | SHEET NO. |
| 343 | * | COOK | 283 | 140 |
| STA. | TO STA. | | | |
| | | | | |
| FED. ROAD DIST. NO. 1 | ILLINOIS | FED. AID PROJECT | | |
| * 700-Y-R & 70HB-R-1 | | 62897 | | |

KEY PLAN

- NOTES:
1. ALL TEMPORARY AERIAL CABLE SHALL BE (3) 1/C #2 ALUMINUM WITH MESSENGER WIRE.
 2. CIRCUIT/POLE NUMBERS OUTSIDE OF PRENTHESES ARE PROPOSED. CIRCUIT/POLE NUMBERS IN PRENTHESES ARE EXISTING NUMBERS AND SHALL BE REPLACED IN ACCORDANCE WITH GENERAL NOTE #34, SHEET LT-02.
 3. MAINTAIN EXISTING LIGHTS IN SERVICE ON NORTH SIDE OF IL-68 WHILE CONSTRUCTION ON SOUTH SIDE IS IN PROGRESS.
 4. MAINTAIN A MINIMUM OF 4.9M CLEARANCE TO GRADE FOR ALL AERIAL CABLES.

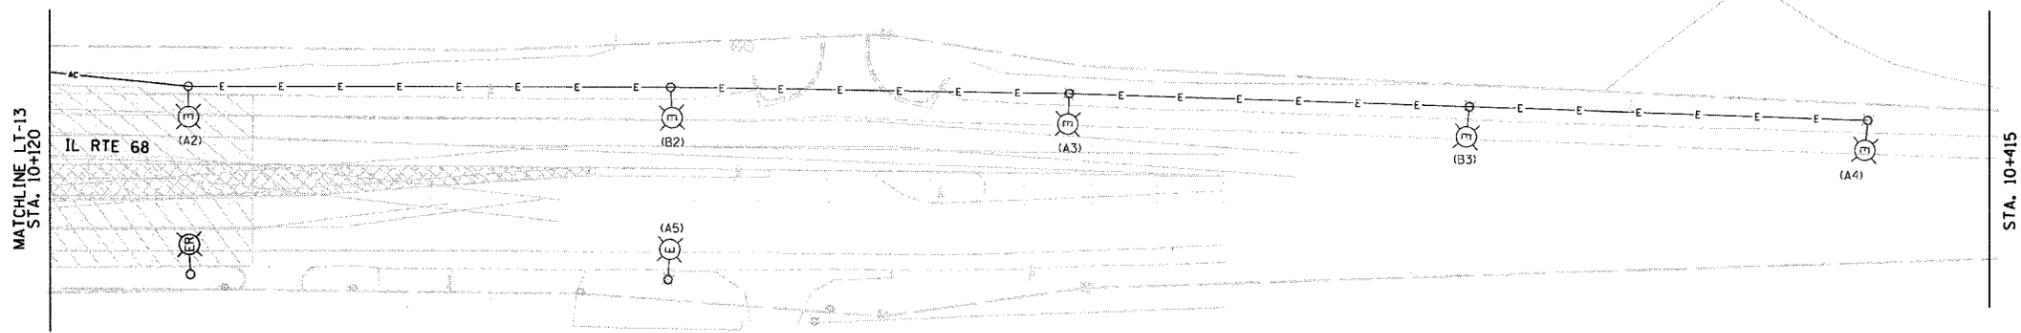

Rick Johns
 IDOT - District 01
 02-05-1001-STV-03 - IL 68 over US 14
 P:02-05-1001-STV-03 - IL 68 over US 14
 11/21/2006 3:39:43 PM
 500.0000 M / M.



| REVISIONS | |
|-----------|------|
| NAME | DATE |
| | |
| | |
| | |
| | |
| | |

LT-15 OF 19

ILLINOIS DEPARTMENT OF TRANSPORTATION
 ILLINOIS ROUTE 68 AT U.S. ROUTE 14
 ROADWAY TEMPORARY LIGHTING PLAN
 IL 68 STA. 10+120 TO STA. 10+415

SCALE 1:500
 DATE NOVEMBER 2006

DRAWN BY R.P.J.
 DESIGNED BY I.B.
 CHECKED BY A.D.O.