
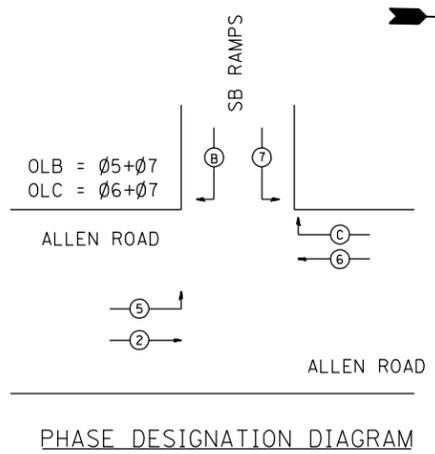
 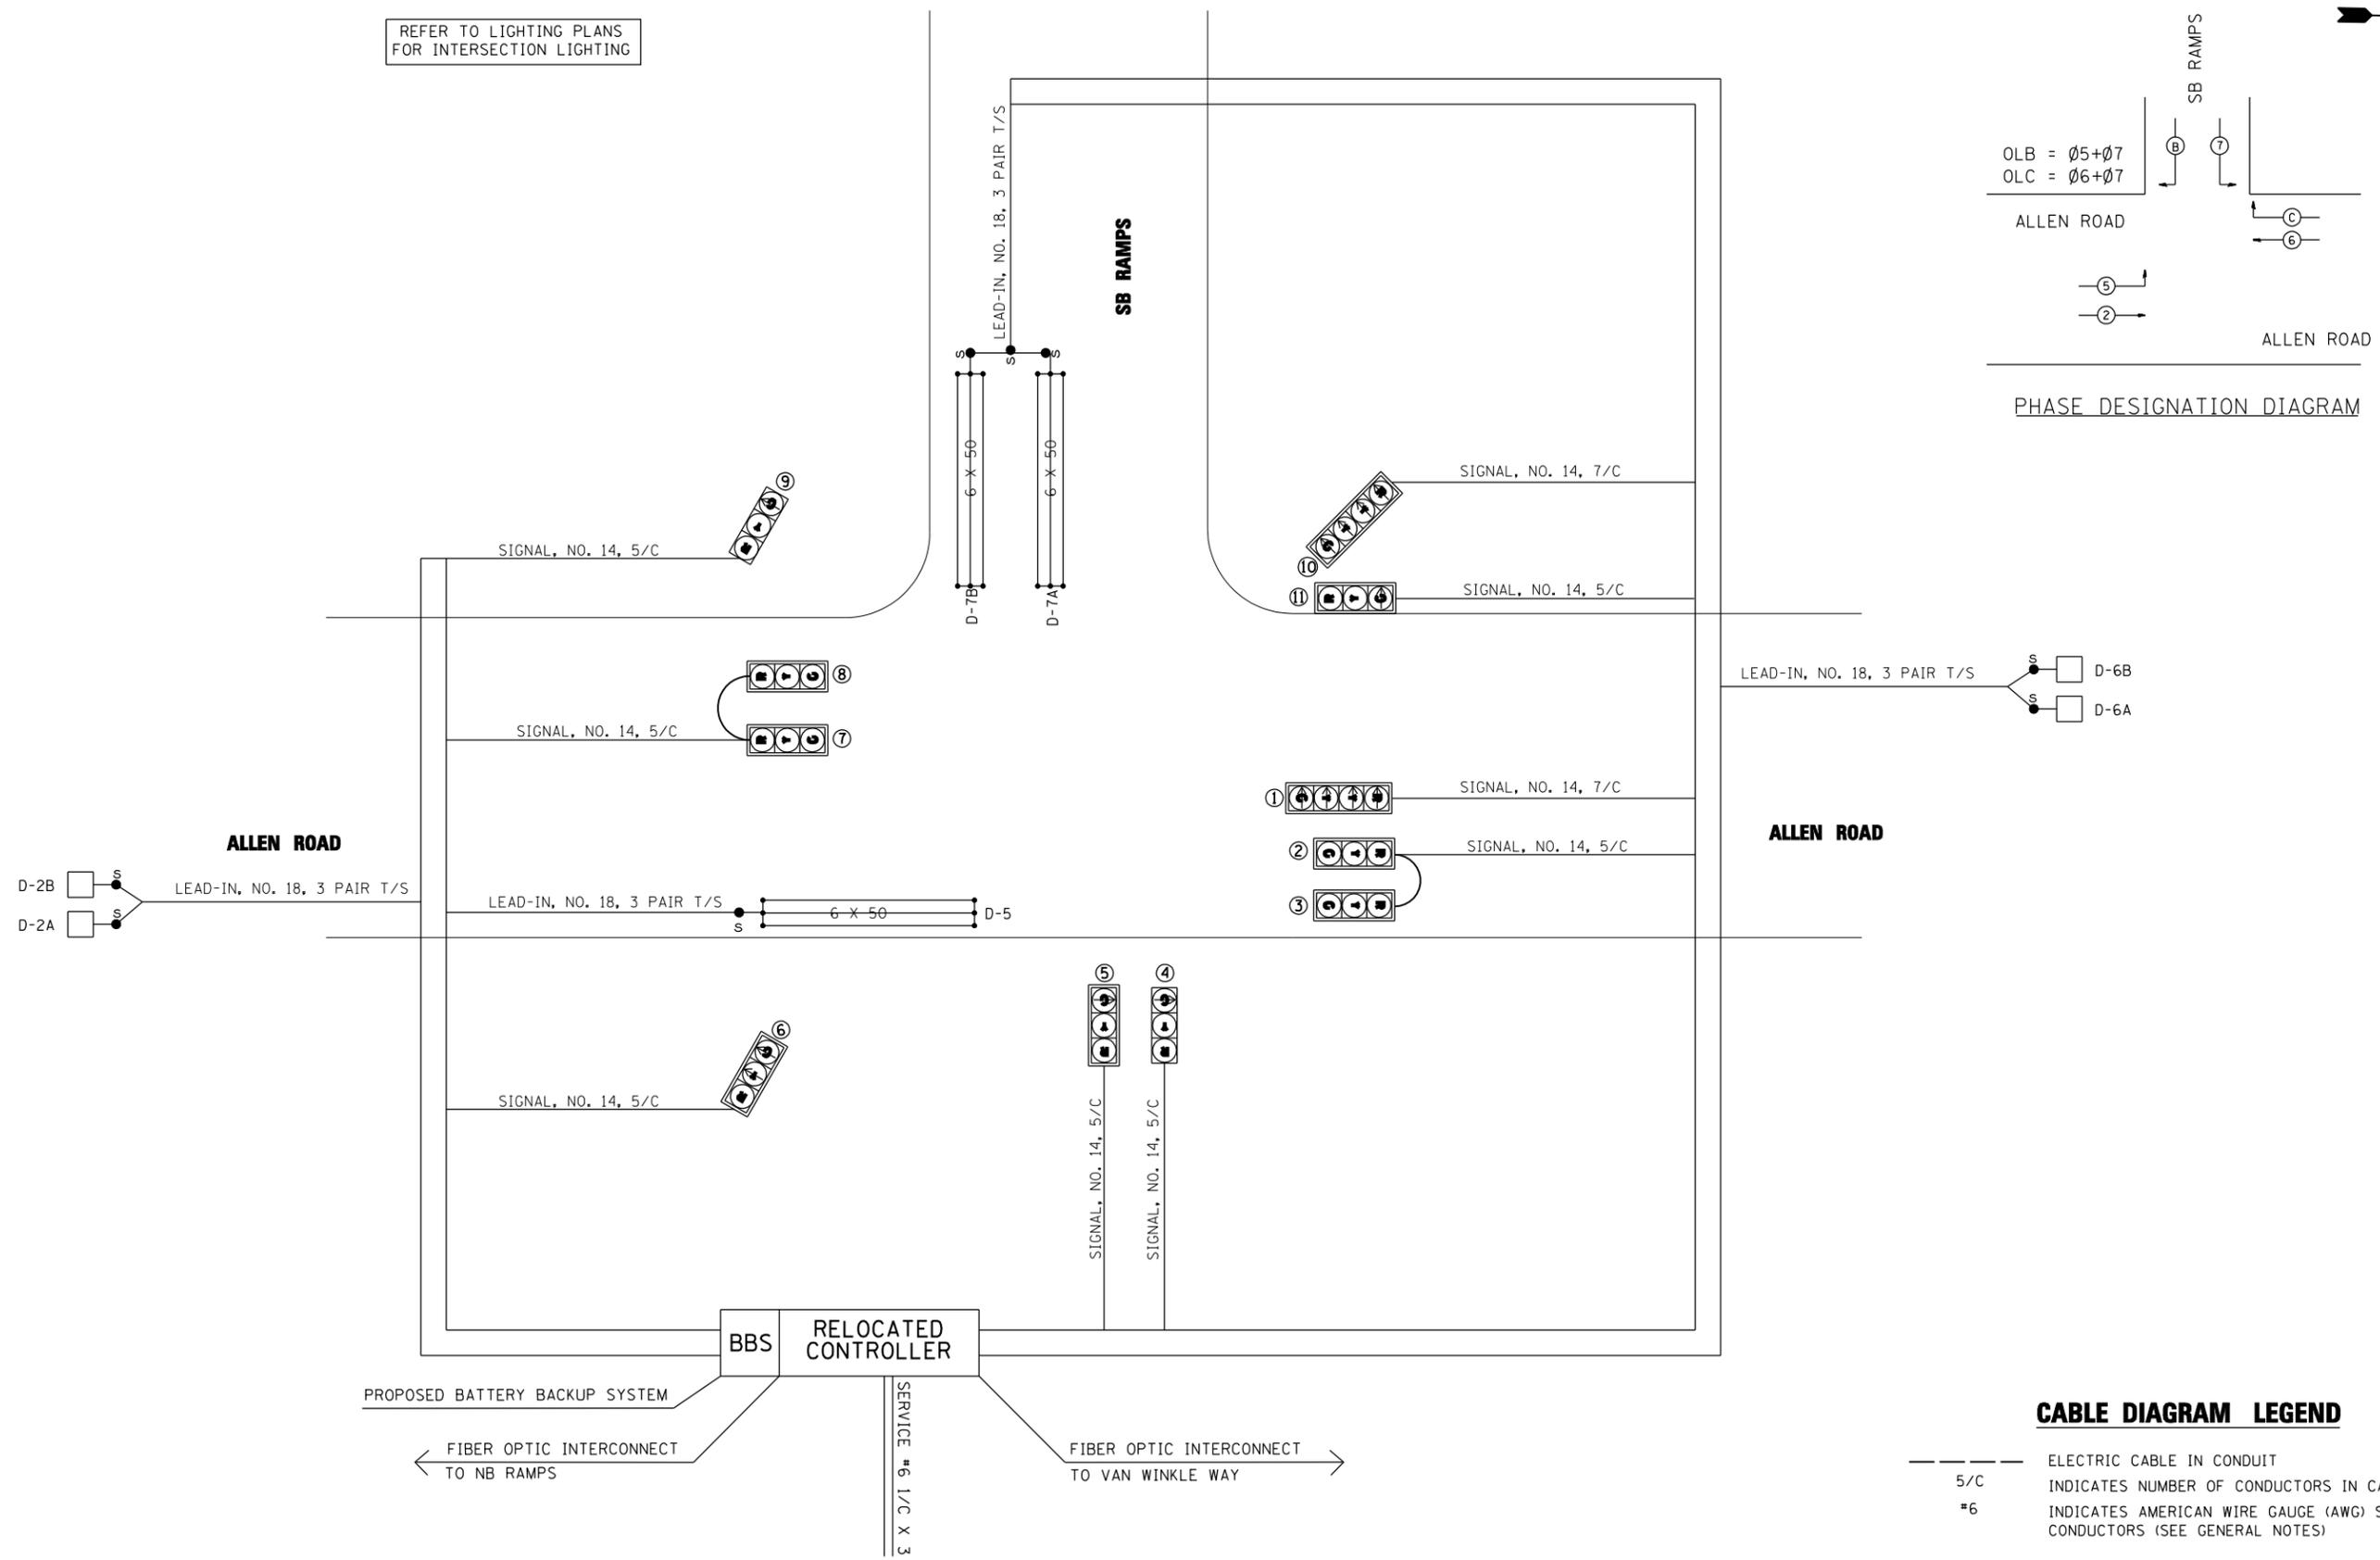


REFER TO LIGHTING PLANS
FOR INTERSECTION LIGHTING



PHASE DESIGNATION DIAGRAM

CABLE DIAGRAM LEGEND

- 5/C — ELECTRIC CABLE IN CONDUIT
- INDICATES NUMBER OF CONDUCTORS IN CABLE
- *6 INDICATES AMERICAN WIRE GAUGE (AWG) SIZE 6 CONDUCTORS (SEE GENERAL NOTES)



FILE NAME = ...D468683-sht-ts2.dgn	USER NAME = JDOT	DESIGNED - LDC	REVISED -
#MODELNAME#	PLOT SCALE = 40.0000' / IN.	DRAWN - SMS	REVISED -
	PLOT DATE = 1/27/2014	CHECKED - GEB	REVISED -
		DATE -	REVISED -

**STATE OF ILLINOIS
DEPARTMENT OF TRANSPORTATION**

**ALLEN ROAD IMPROVEMENTS
TRAFFIC SIGNAL CABLE AND PHASE DIAGRAMS
IL 6 SB RAMPS & ALLEN ROAD**

SCALE: SHEET 7 OF 11 SHEETS STA. TO STA.

F.A.U. RTE.	SECTION	COUNTY	TOTAL SHEETS	SHEET NO.
6584	105	PEORIA	487	257
CONTRACT NO. 68683				
ILLINOIS FED. AID PROJECT				