

**SOUTHERN ILLINOIS
AIRPORT**

**MURPHYSBORO /
CARBONDALE,
ILLINOIS**

REMOVE TAXIWAY D

IDA No: MDH-4304

Contract No:


SBG No: SBG-TBD

NO.	DATE	DESCRIPTION		
		LAY	DWN	REV

ISSUE: MARCH 07, 2014
PROJECT NO: 13A0083D
CAD FILE: E-503-DETL.DWG
LAYOUT BY: KNL 02/25/2014
DRAWN BY: CWS 02/25/2014
REVIEWED BY: JSL 03/05/2014

© Copyright Hanson Professional Services Inc. 2014
SHEET TITLE

**ELECTRICAL DETAILS
SHEET 3**

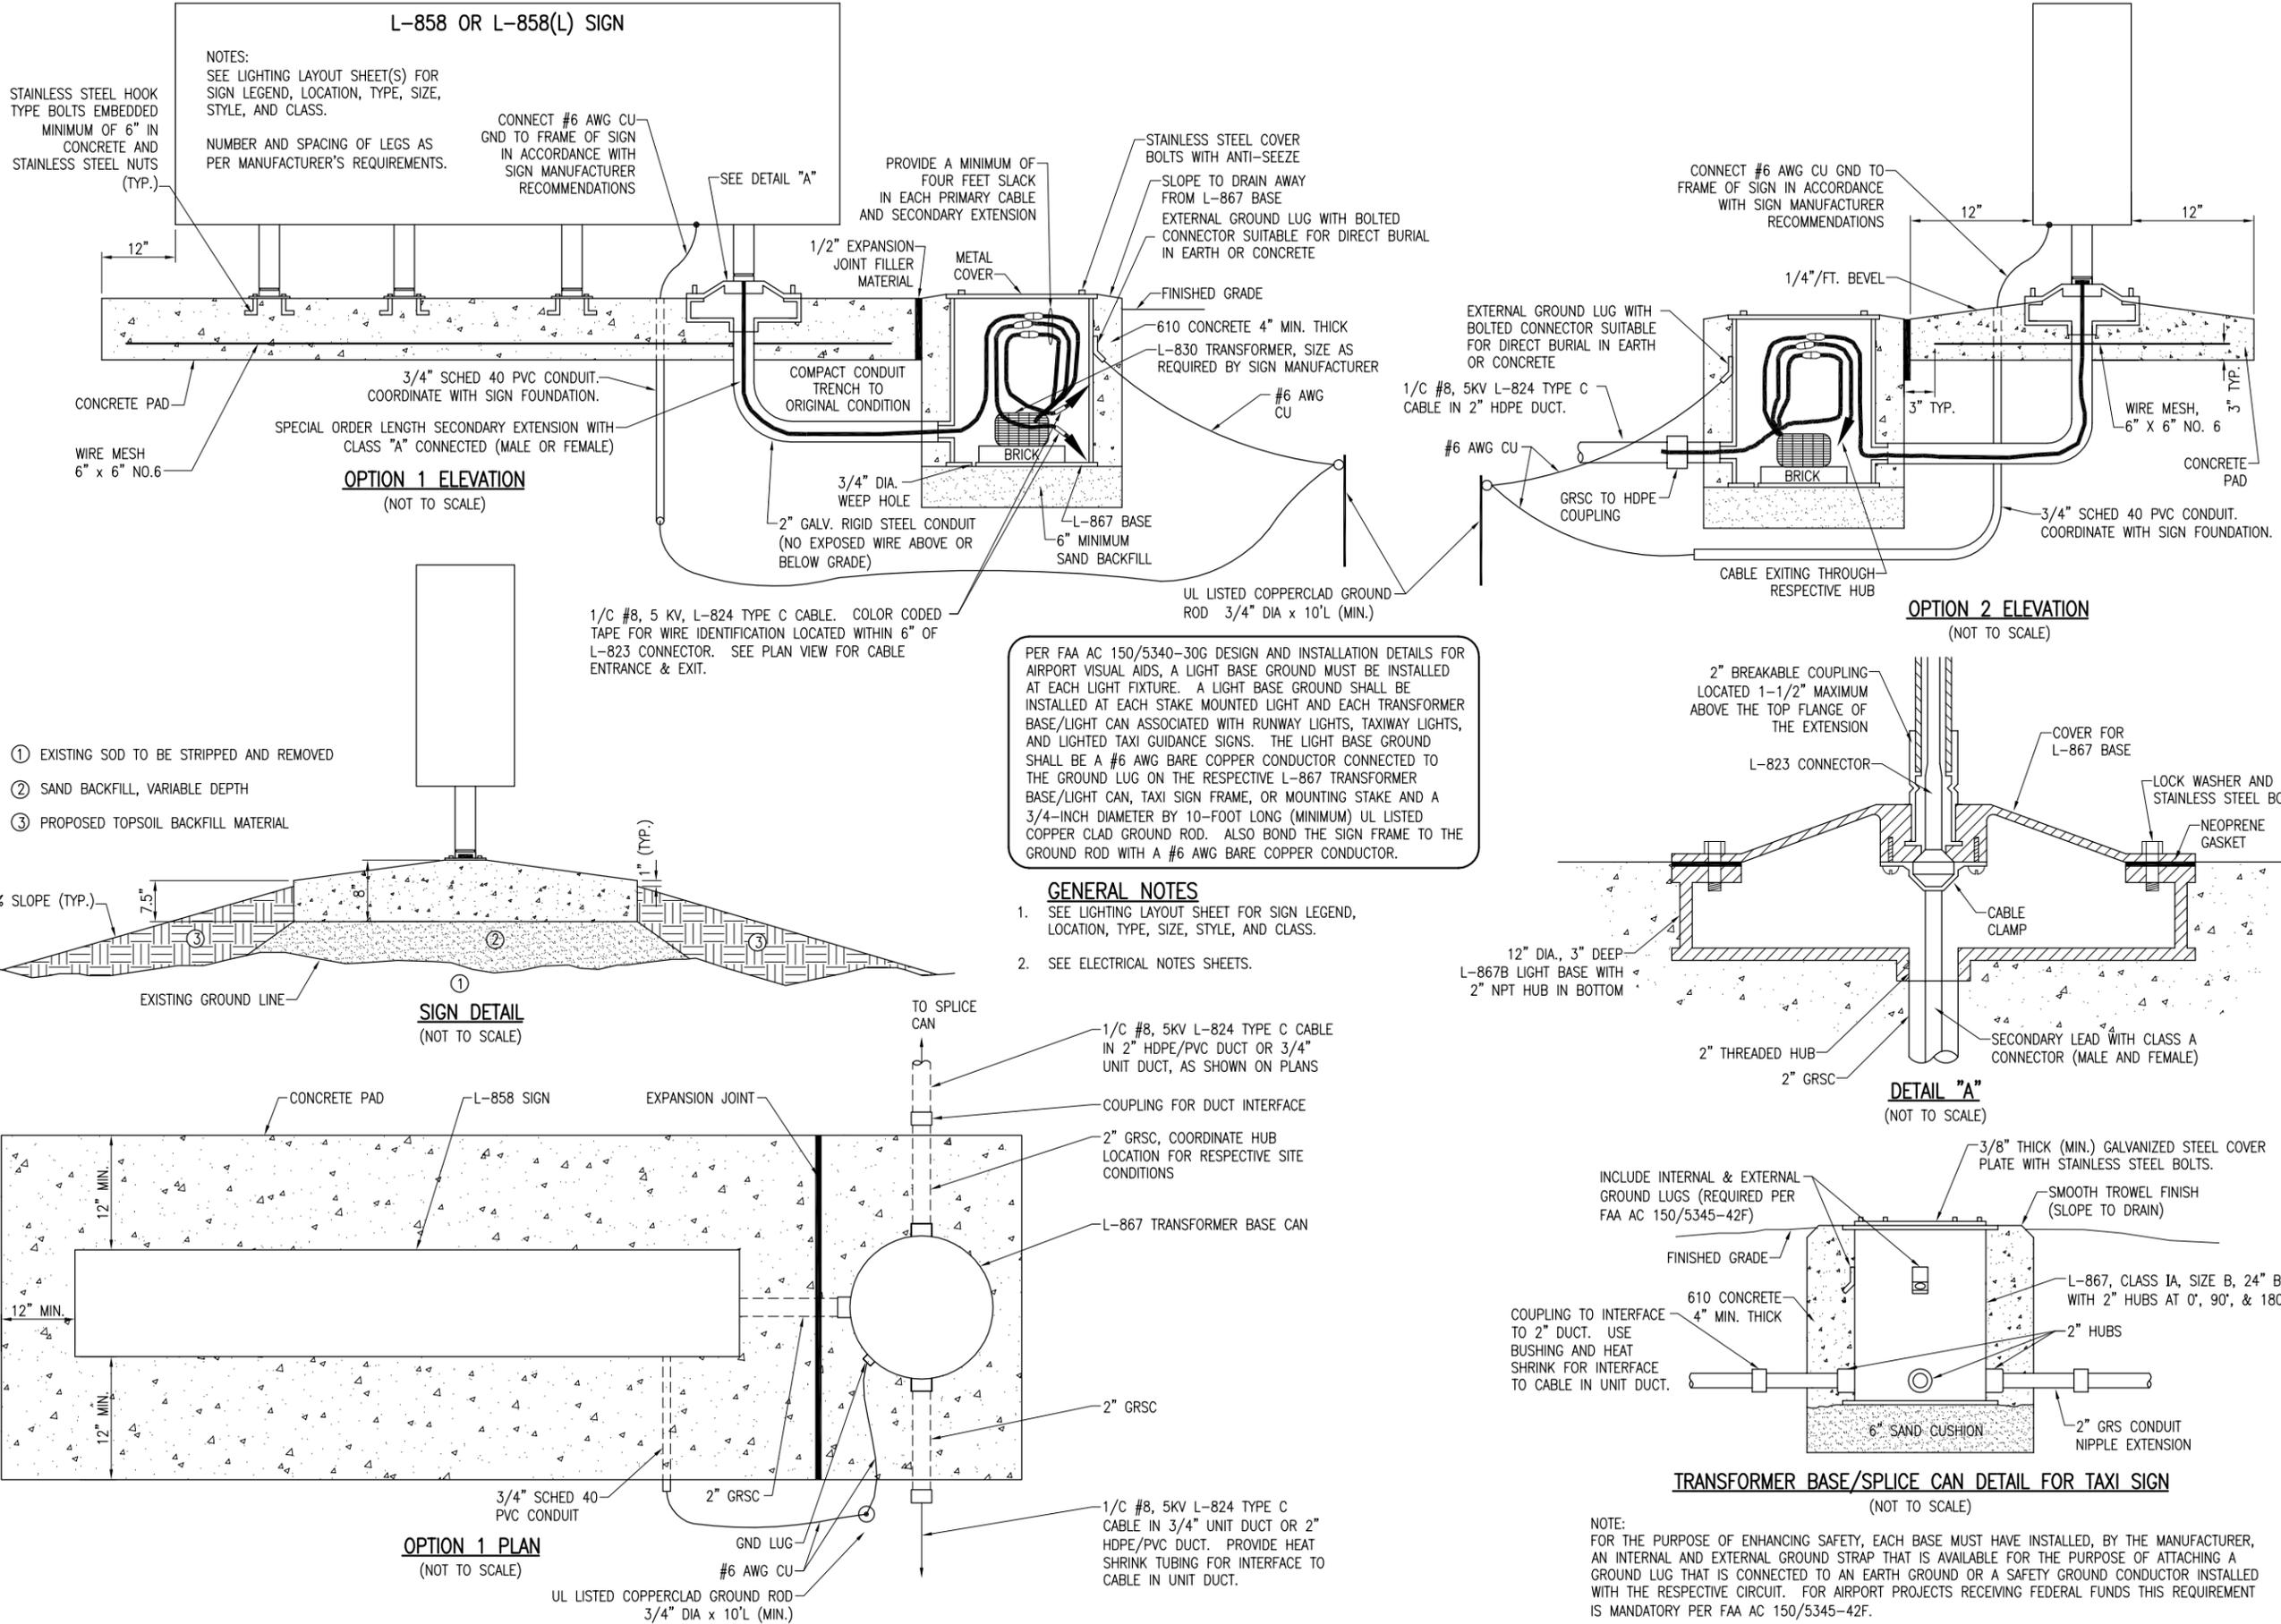

MAR 05, 2014 3:11 PM SCHUB01446