


**NOTES:**

1. UTILIZE EXISTING CONDUIT ENTRANCES IN FOUNDATION TO ROUTE NEW UNIT DUCT TO EXISTING LIGHT POLE. REMOVE AND REPLACE EXISTING FUSE KIT AT POLE BASE.
2. EXISTING DIRECT BURIAL CABLE SHALL BE ABANDONED IN PLACE AFTER INSTALLATION AND CONNECTION OF NEW UNIT DUCT.
3. REMOVE EXISTING UNIT DUCT FROM CONDUIT. THIS WORK WILL BE PAID FOR AS "REMOVE ELECTRIC CABLE FROM CONDUIT."

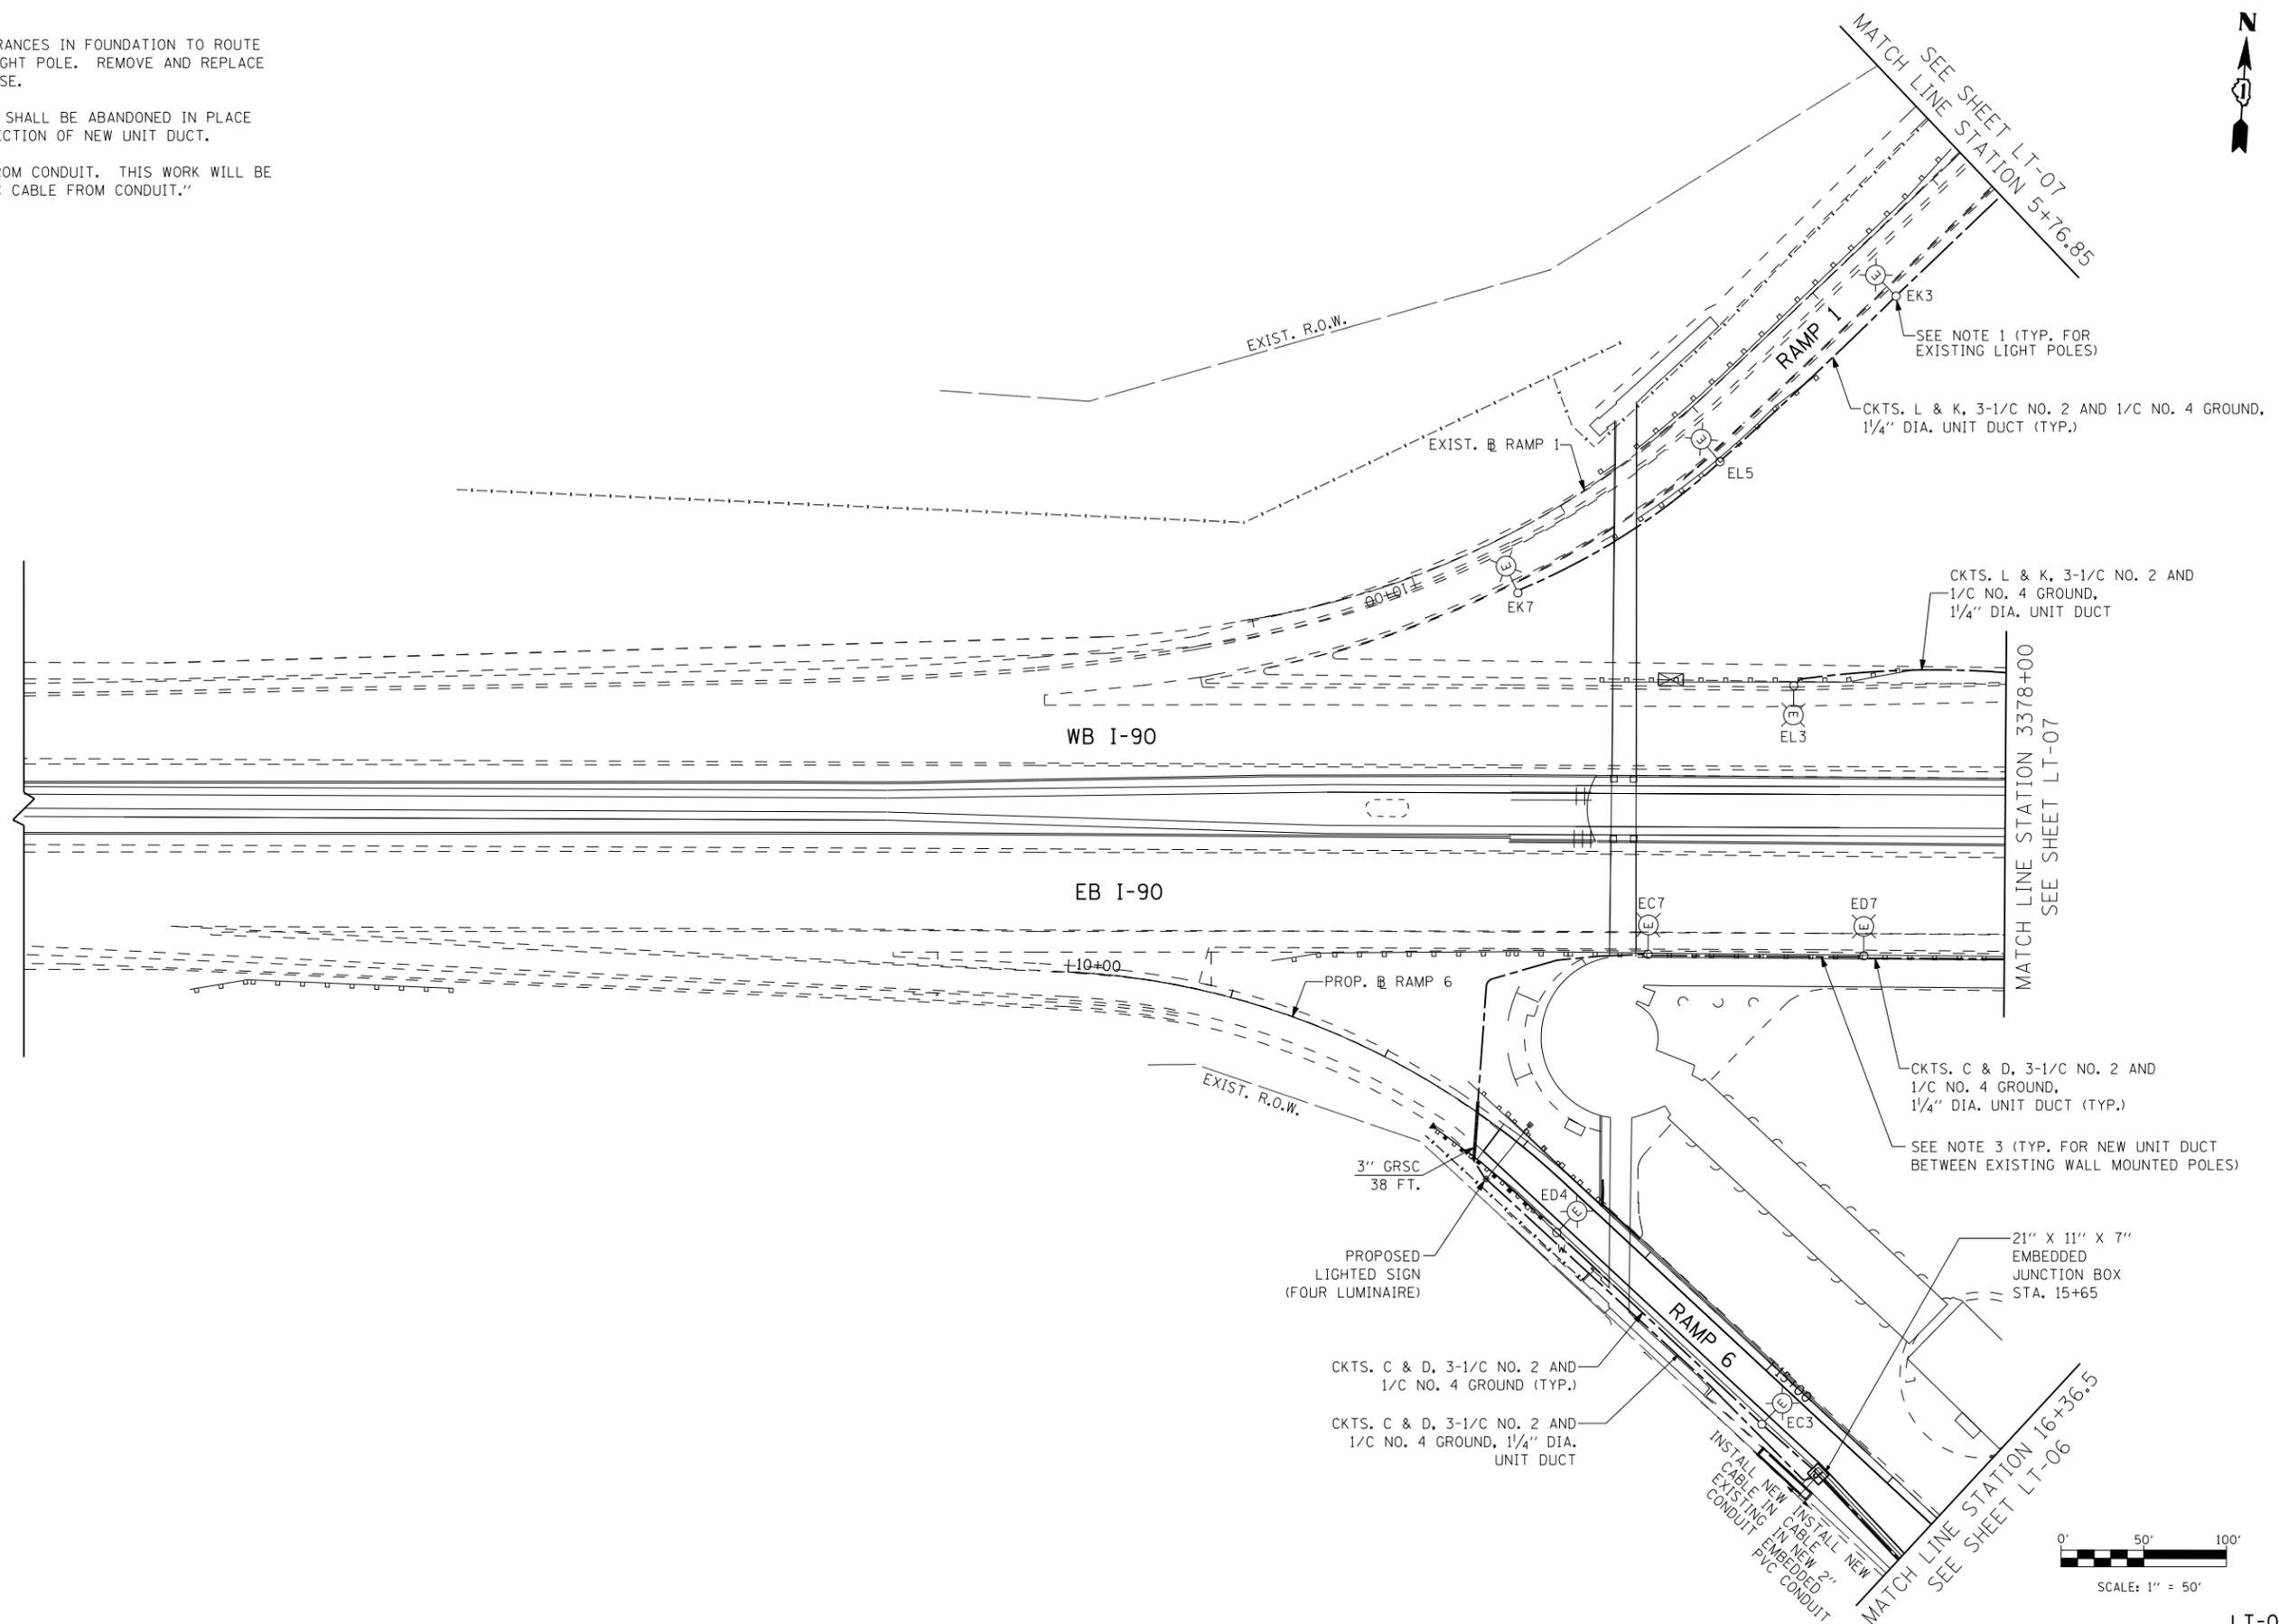

s:\projects\3009 1-90\_cumberland-patrick\project work\disciplines\electrical\sheet\DI60J14-sht-light.05.dgn

2/18/2013 2:43:21 PM

2/18/2013

USER NAME =	DESIGNED - RAS	REVISED -
	DRAWN - RAS	REVISED -
PLOT SCALE =	CHECKED - MKR	REVISED -
PLOT DATE =	DATE - 2/18/2013	REVISED -

 


**STATE OF ILLINOIS  
DEPARTMENT OF TRANSPORTATION**

**PROPOSED IDOT LIGHTING PLAN  
I-90 AT CUMBERLAND AVENUE**

SCALE: 1" = 50'    SHEET NO. 1 OF 6 SHEETS    STA. 3366+00 TO STA. 3378+00

F.A.U. RTE.	SECTION	COUNTY	TOTAL SHEETS	SHEET NO.
2746	1616B	COOK	404	237
CONTRACT NO. 60J14				
ILLINOIS FED. AID PROJECT				



LT-05