


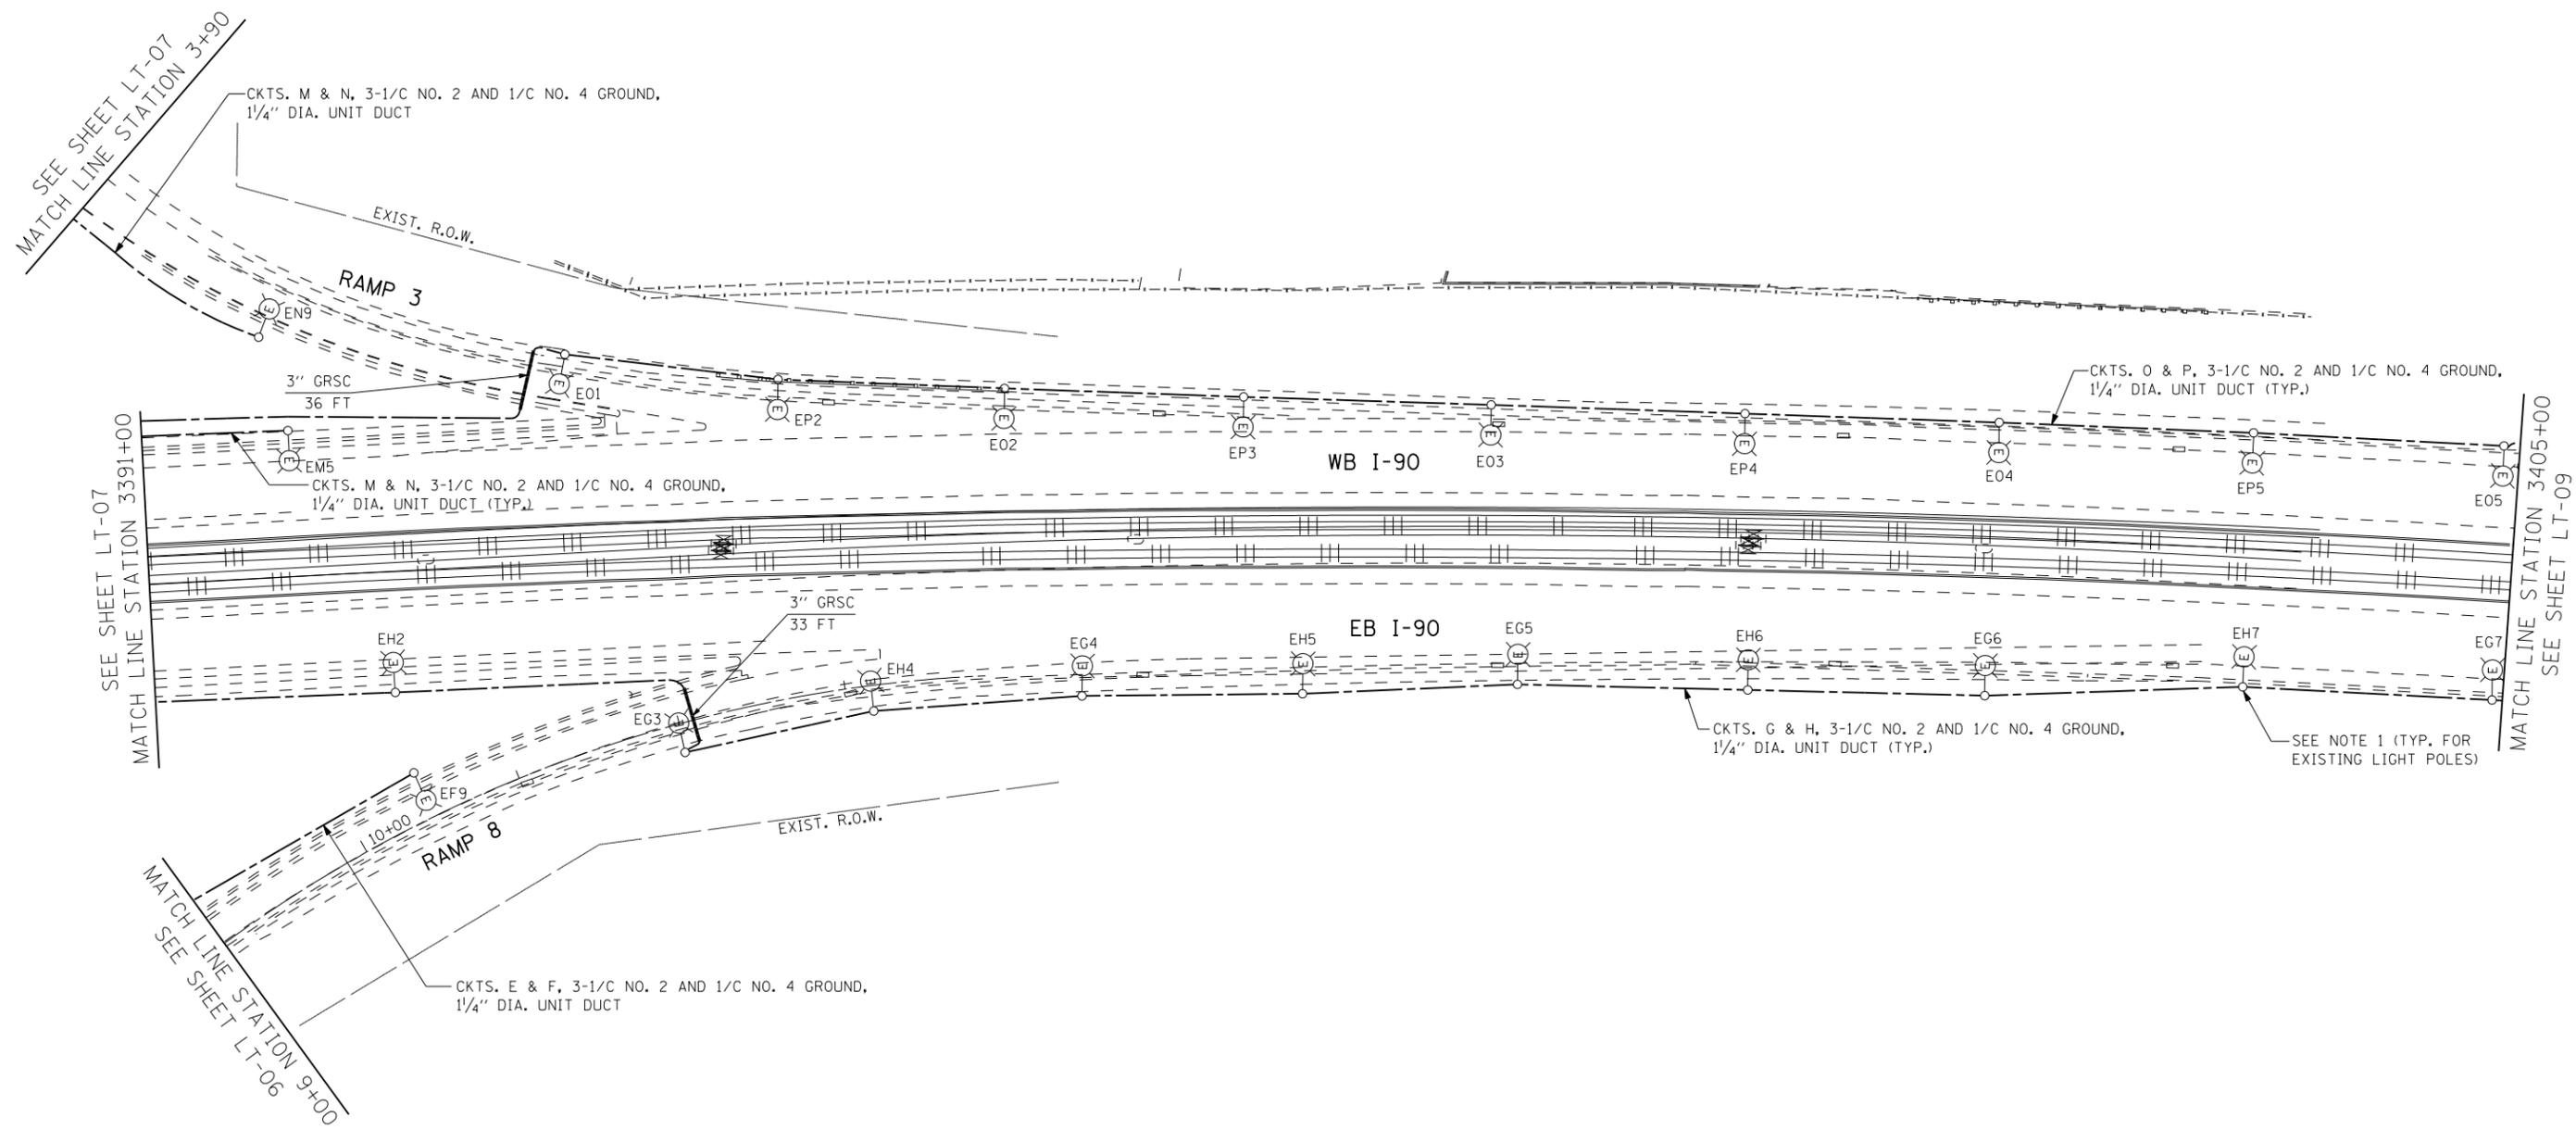


- NOTES:
1. UTILIZE EXISTING CONDUIT ENTRANCES IN FOUNDATION TO ROUTE NEW UNIT DUCT TO EXISTING LIGHT POLE. REMOVE AND REPLACE EXISTING FUSE KIT AT POLE BASE.
 2. EXISTING DIRECT BURIAL CABLE SHALL BE ABANDONED IN PLACE AFTER INSTALLATION AND CONNECTION OF NEW UNIT DUCT.



s:\projects\3009 1-90_cumberland-patrick\project work\disciplines\electrical\sheet\DI60J14-sht-light.08.dgn

2/18/2013 2:43:28 PM

 2/18/2013



| | | |
|--------------|------------------|-----------|
| USER NAME = | DESIGNED - RAS | REVISED - |
| | DRAWN - RAS | REVISED - |
| PLOT SCALE = | CHECKED - MKR | REVISED - |
| PLOT DATE = | DATE - 2/18/2013 | REVISED - |



**STATE OF ILLINOIS
DEPARTMENT OF TRANSPORTATION**

**PROPOSED IDOT LIGHTING PLAN
I-90 AT CUMBERLAND AVENUE**

SCALE: 1" = 50' SHEET NO. 4 OF 6 SHEETS STA. 3391+00 TO STA. 3405+00

| | | | | |
|---------------------------|---------|--------|--------------|-----------|
| F.A.U. RTE. | SECTION | COUNTY | TOTAL SHEETS | SHEET NO. |
| 2746 | 1616B | COOK | 404 | 240 |
| CONTRACT NO. 60J14 | | | | |
| ILLINOIS FED. AID PROJECT | | | | |

LT-08