




- NOTES:**
1. REFER TO TRAFFIC SIGNAL PLANS FOR LOCATIONS OF COMBINATION MAST ARM POLES.
 2. PROPOSED LIGHT POLES ON THIS SHEET SHALL BE 47.5' M.H., WITH 8' MAST ARM AND 400W MCIII LUMINAIRE.
 3. (3) EXISTING CITY OF PARK RIDGE EMBEDDED LIGHT POLES ALONG HIGGINS ROAD (LOCATED AT STA. 9+05, 59 FT LT, STA. 10+22, 58 FT LT, AND STA. 17+10, 46 FT LT) SHALL BE REMOVED. REMOVAL OF AERIAL CABLE CONNECTED TO THESE LIGHTING UNITS IS INCLUDED IN THE COST OF THE ITEM "REMOVAL OF LIGHTING UNIT, NO SALVAGE."
 4. THE CONTRACTOR SHALL FIELD VERIFY THE LOCATIONS OF EXISTING CHICAGO DEPARTMENT OF WATER MANAGEMENT FACILITIES IN THIS AREA PRIOR TO PERFORMING ANY INSTALLATION WORK. THE PRECISE LOCATION OF THE FOUNDATION SHALL BE COORDINATED IN THE FIELD WITH A DEPARTMENT OF WATER MANAGEMENT REPRESENTATIVE.

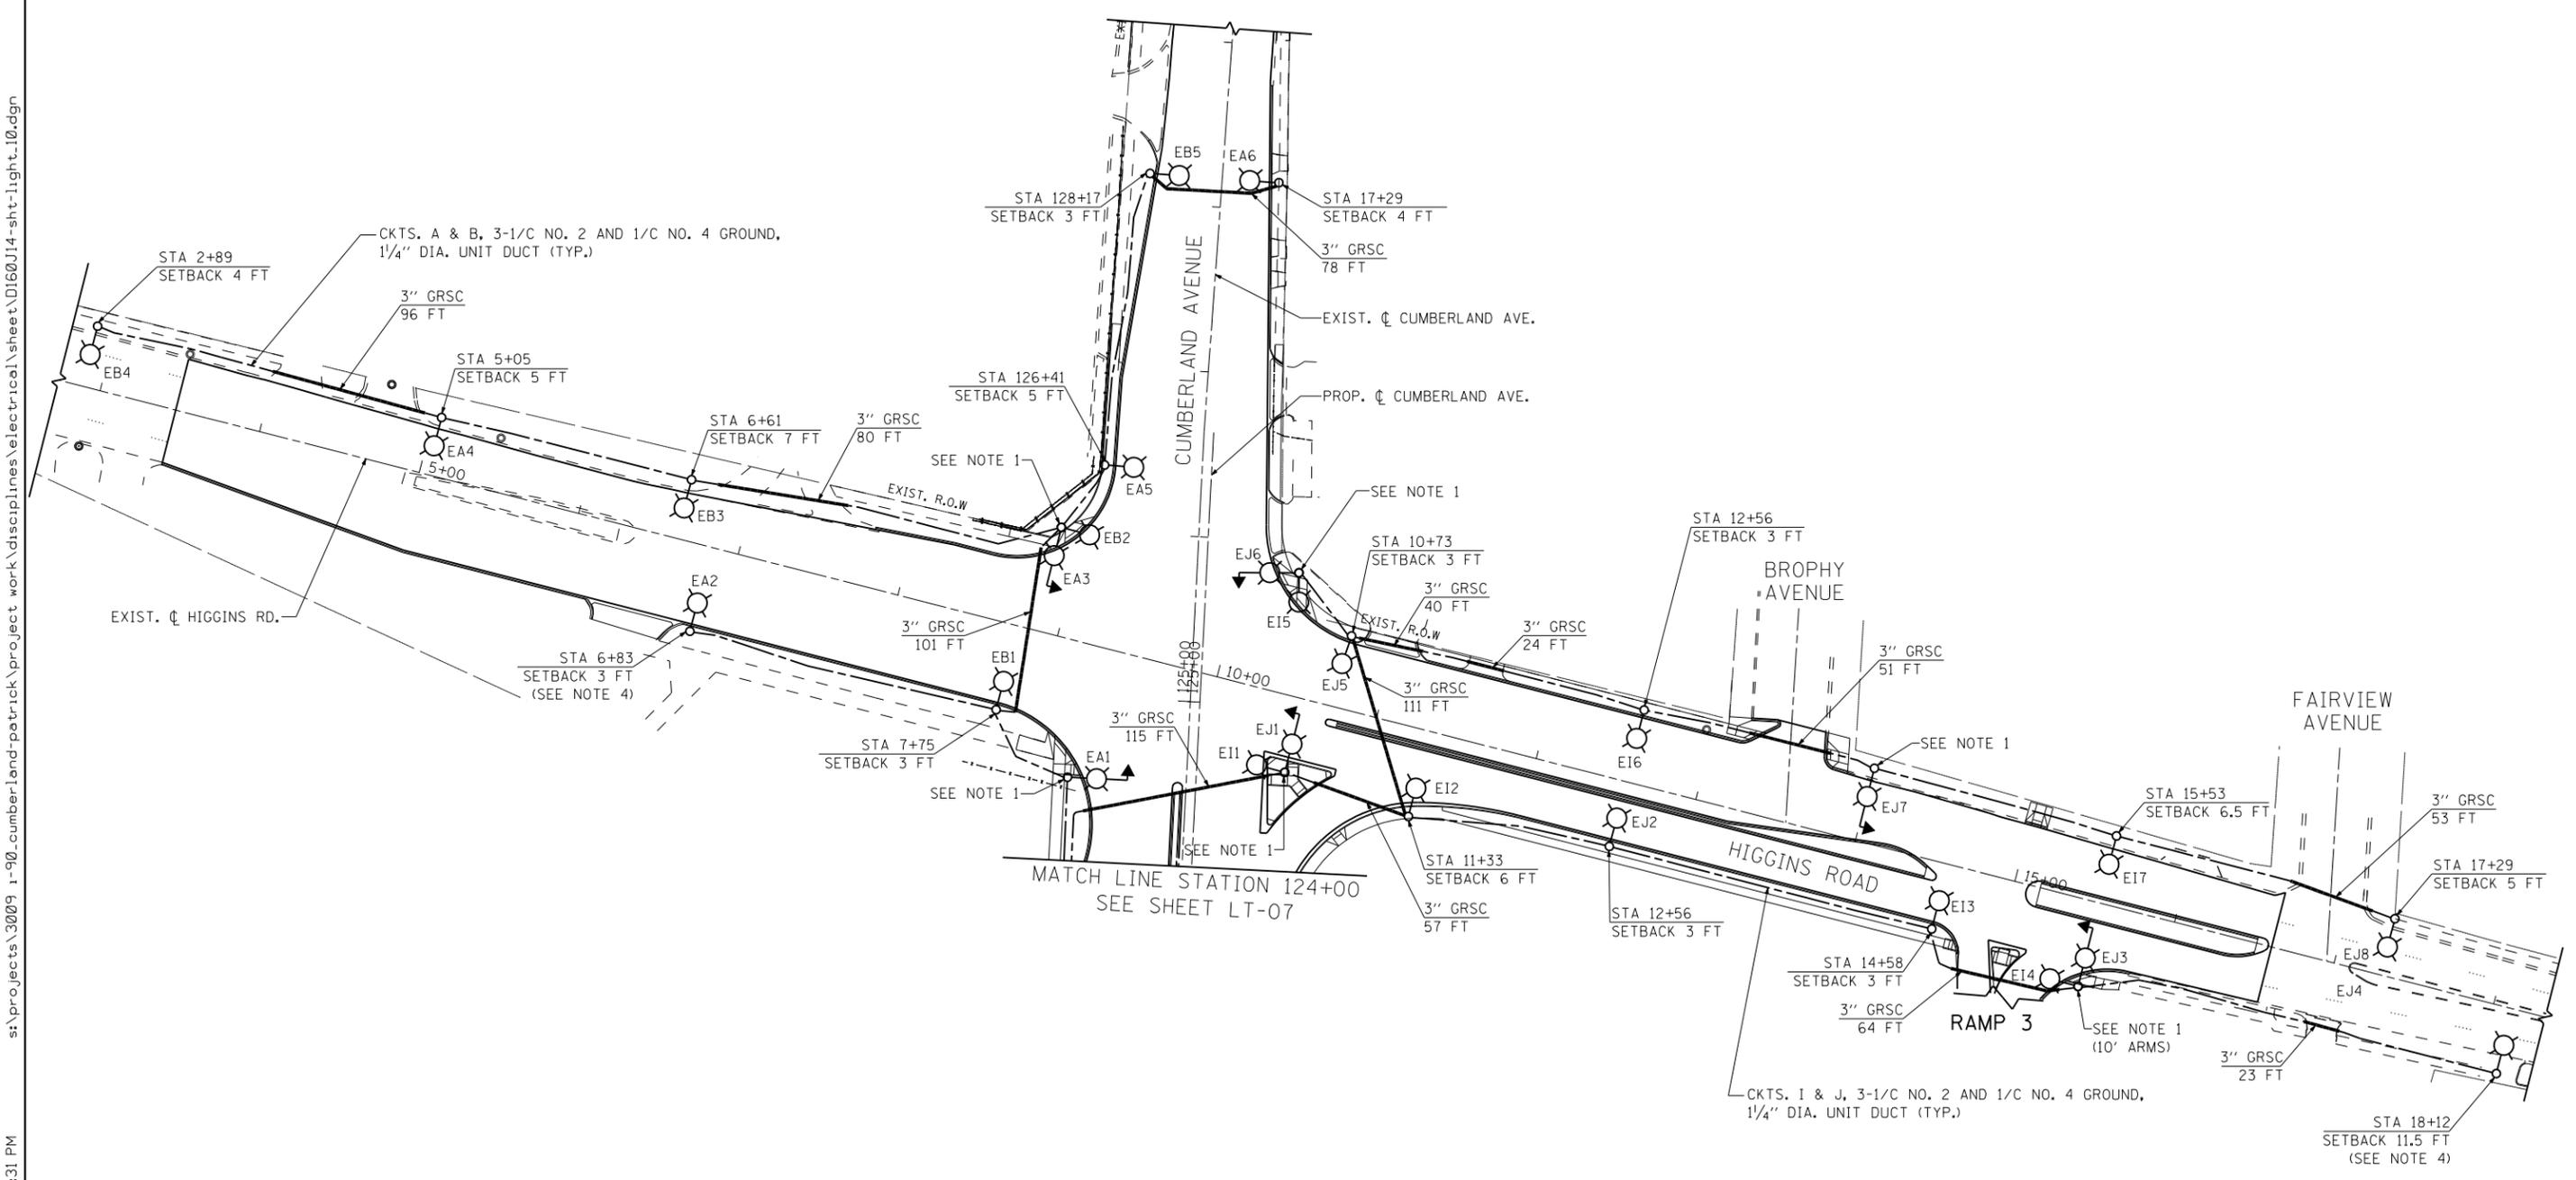

CKTS. I & J, 3-1/2 NO. 2 AND 1/2 NO. 4 GROUND, 1/4" DIA. UNIT DUCT (TYP.)



s:\projects\3009 1-90_cumberland-patrick-work\disciplines\electrical\sheet\DI60J14-sht-light-10.dgn

2/18/2013 2:43:31 PM

USER NAME =	DESIGNED - RAS	REVISED -
	DRAWN - RAS	REVISED -
PLOT SCALE =	CHECKED - MKR	REVISED -
PLOT DATE =	DATE - 2/18/2013	REVISED -



**STATE OF ILLINOIS
DEPARTMENT OF TRANSPORTATION**

**PROPOSED IDOT LIGHTING PLAN
CUMBERLAND AVENUE AT HIGGINS ROAD**

SCALE: 1" = 50' SHEET NO. 6 OF 6 SHEETS STA. TO STA.

F.A.U. RTE.	SECTION	COUNTY	TOTAL SHEETS	SHEET NO.
2746	1616B	COOK	404	242
CONTRACT NO. 60J14				
ILLINOIS FED. AID PROJECT				

LT-10