




MATCH LINE SEE DRAWING EX-12
WEST FRONTAGE CONNECTOR
STA. 6086+50.00

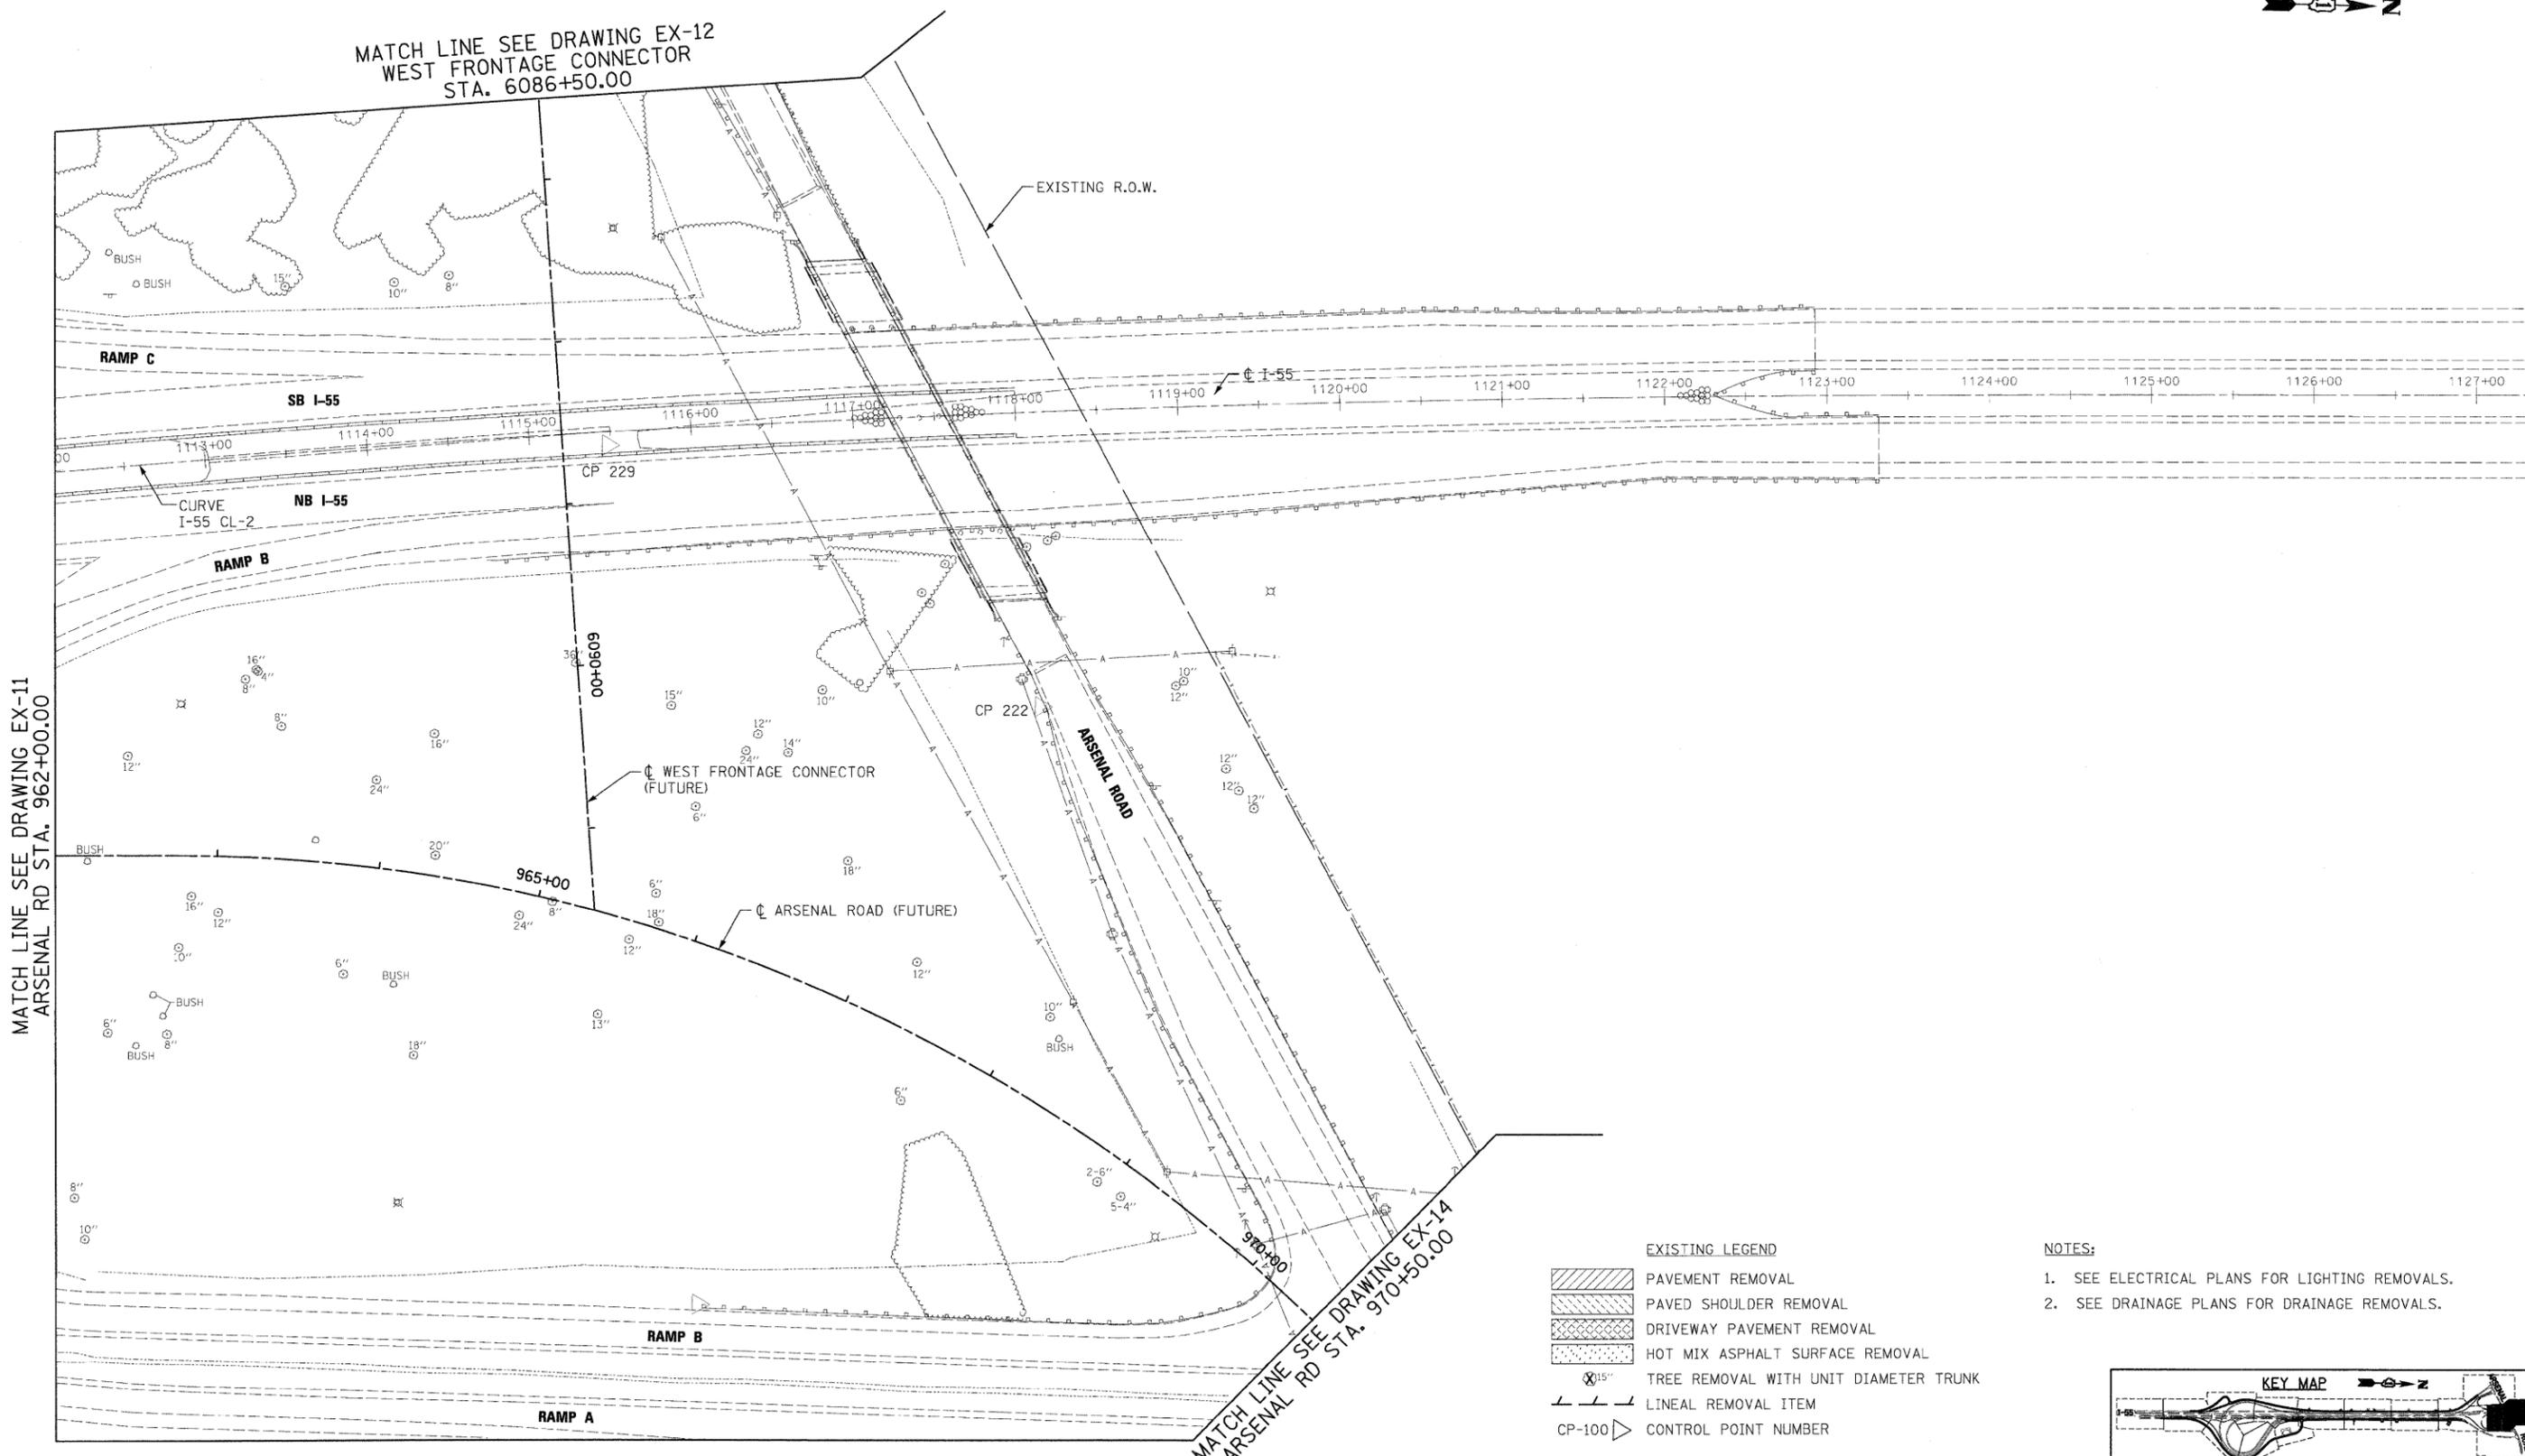


MATCH LINE SEE DRAWING EX-11
ARSENAL RD STA. 962+00.00

MATCH LINE SEE DRAWING EX-14
ARSENAL RD STA. 970+50.00

- EXISTING LEGEND**
- PAVEMENT REMOVAL
 - PAVED SHOULDER REMOVAL
 - DRIVEWAY PAVEMENT REMOVAL
 - HOT MIX ASPHALT SURFACE REMOVAL
 - TREE REMOVAL WITH UNIT DIAMETER TRUNK
 - LINEAL REMOVAL ITEM
 - CP-100 CONTROL POINT NUMBER

- NOTES:**
1. SEE ELECTRICAL PLANS FOR LIGHTING REMOVALS.
 2. SEE DRAINAGE PLANS FOR DRAINAGE REMOVALS.

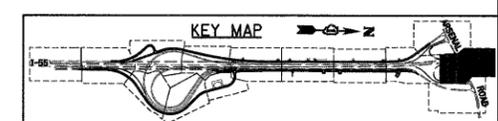

McDonough Associates Inc.
 Engineers / Architects
 130 East Randolph Street, Chicago, Illinois 60601

FILE NAME = D160C31-SHT-REM13.dgn	USER NAME = TKluegel	DESIGNED - JTF	REVISED -
		DRAWN - JTF	REVISED -
		CHECKED - DLT	REVISED -
		DATE - 12/18/09	REVISED -

**STATE OF ILLINOIS
DEPARTMENT OF TRANSPORTATION**

EXISTING PLAN AND REMOVALS

SCALE: 1"=50'	SHEET NO. 13 OF 15 SHEETS	STA. TO STA.	F.A.I. RTE. 55	SECTION (99-1&2)AC-3	COUNTY WILL	TOTAL SHEETS 524	SHEET NO. 50
---------------	---------------------------	--------------	----------------	----------------------	-------------	------------------	--------------

CONTRACT NO. 60C31	
FED. ROAD DIST. NO. 1 ILLINOIS FED. AID PROJECT	