



PLAN	SURVEYED	BY	DATE
	PLOTTED		
	NOTE BOOK		
	NO.		
	CHECKED		
	FILE NAME		

PROFILE	SURVEYED	BY	DATE
	PLOTTED		
	GRADES CHECKED		
	STRUCTURE		
	NOTATIONS CHECKED		
	NO.		

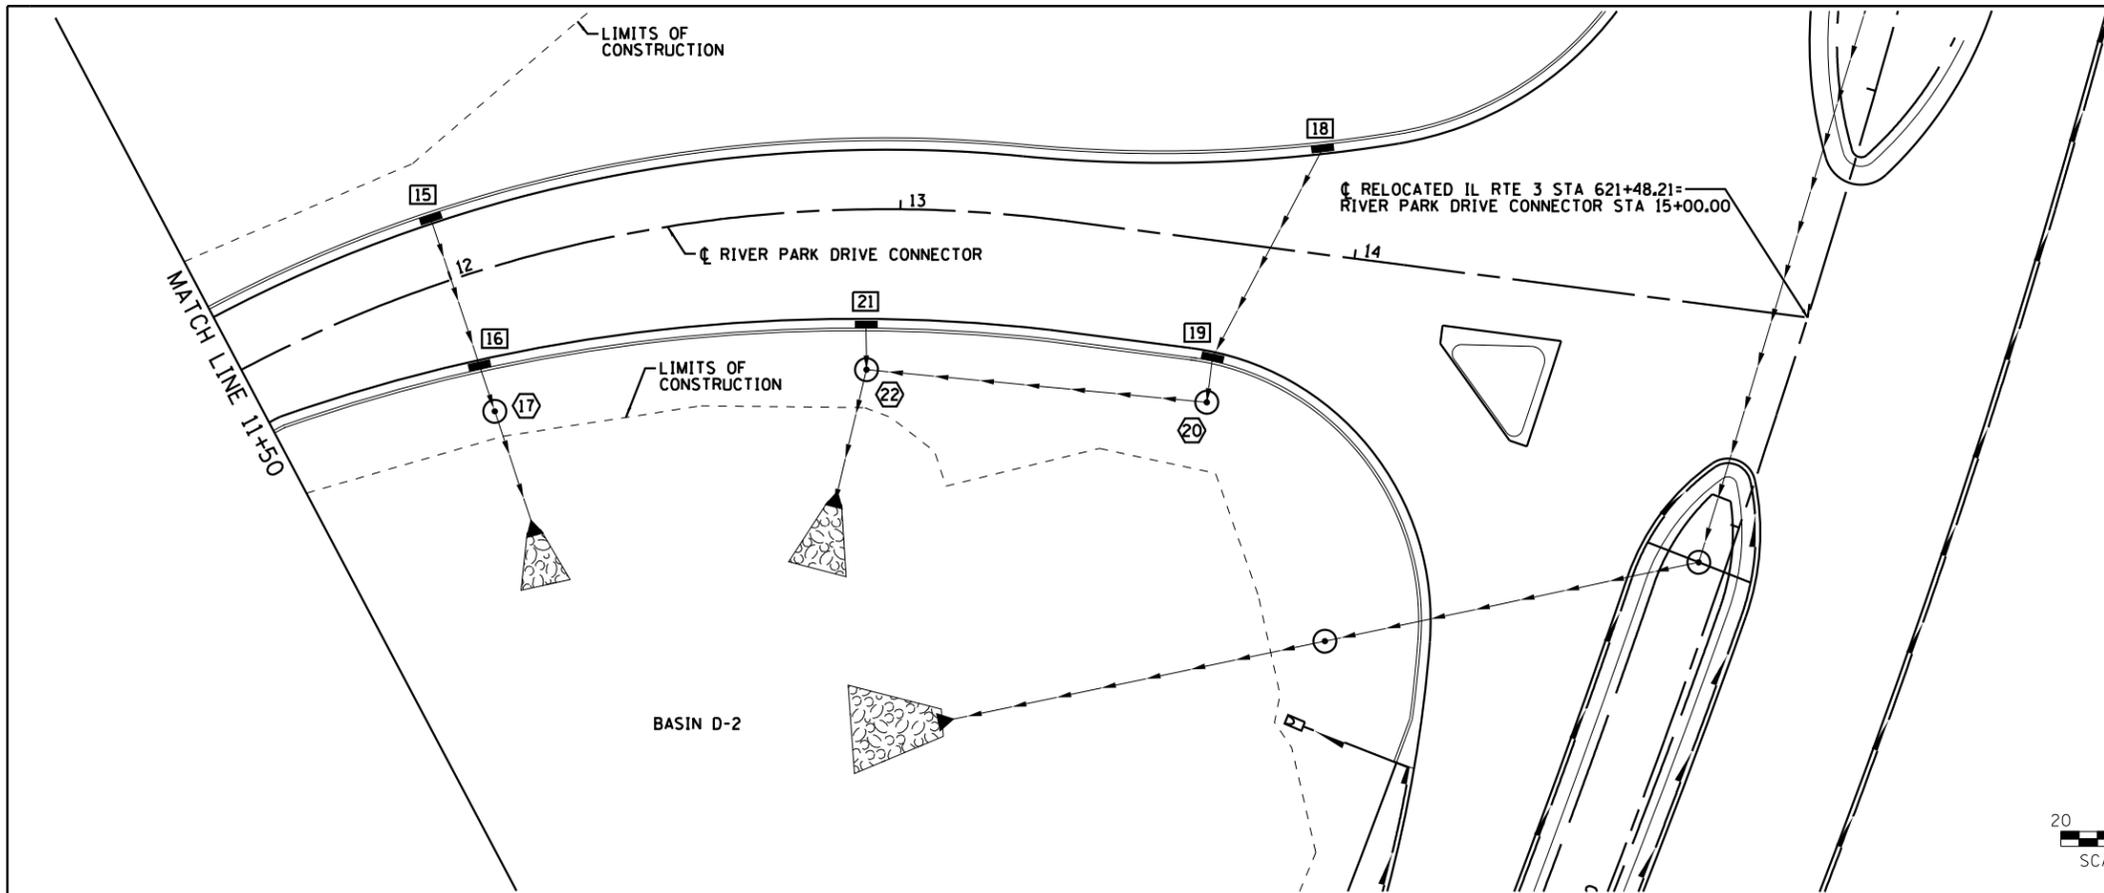

- 15 STA 12+00, 15.6' LT INLETS TO BE ADJUSTED WITH NEW TYPE 3 FRAME AND GRATE  
TC = 424.30
- 16 STA 12+00, 21.1' RT INLETS TO BE ADJUSTED WITH NEW TYPE 3 FRAME AND GRATE  
TC = 423.04
- 17 STA 12+00, 30.3' RT MANHOLES TO BE ADJUSTED WITH NEW TYPE 1 FRAME, CLOSED LID  
RIM = 423.17
- 18 STA 13+90, 24.4' LT INLETS TO BE ADJUSTED WITH NEW TYPE 3 FRAME AND GRATE  
TC = 427.02
- 19 STA 13+72, 26.8' RT INLETS TO BE ADJUSTED WITH NEW TYPE 3 FRAME AND GRATE  
TC = 426.87
- 20 STA 13+72, 35.3' RT MANHOLES TO BE ADJUSTED WITH NEW TYPE 1 FRAME, CLOSED LID  
RIM = 427.00
- 21 STA 12+92, 26.5' RT INLETS TO BE ADJUSTED WITH NEW TYPE 3 FRAME AND GRATE  
TC = 424.37
- 22 STA 12+92, 35.0' RT MANHOLES TO BE ADJUSTED WITH NEW TYPE 1 FRAME, CLOSED LID  
RIM = 424.50

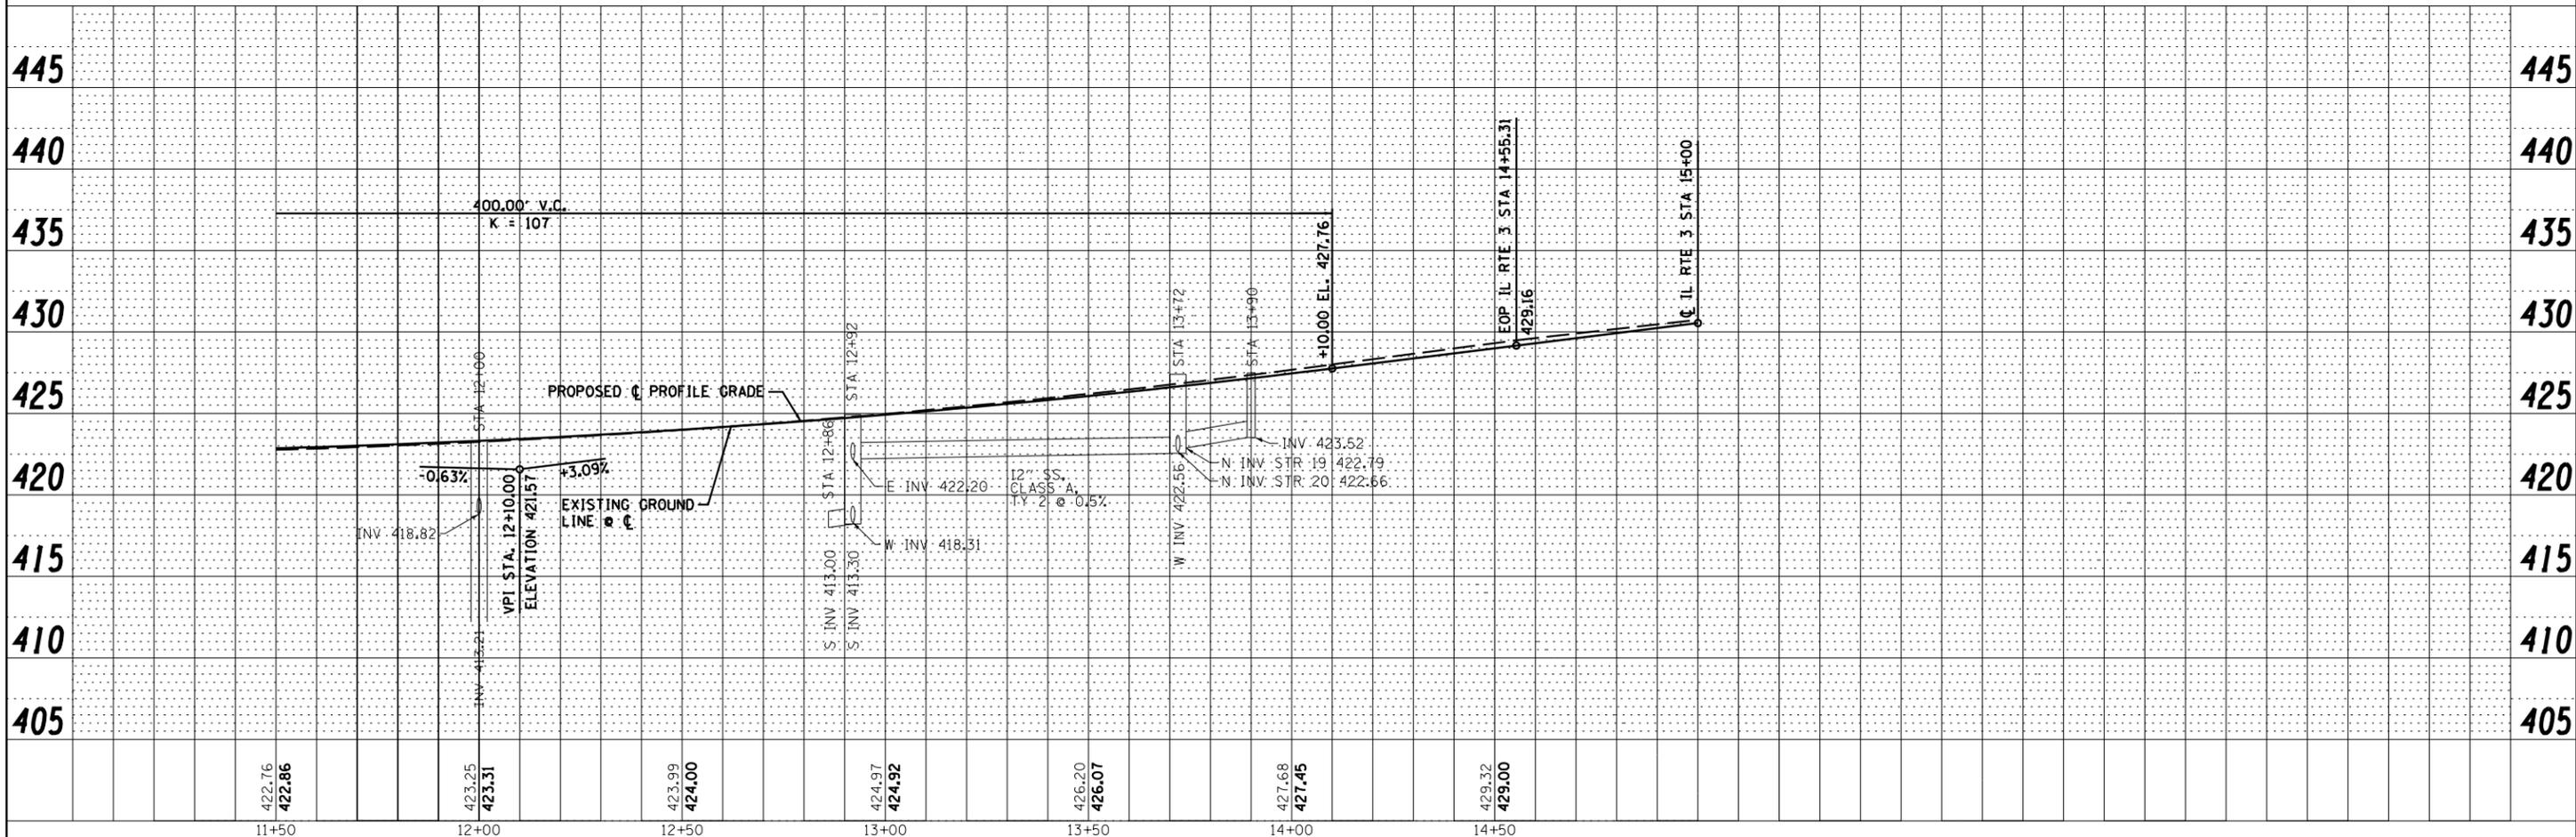

<p>Farnsworth GROUP, INC. 2709 McGraw Drive Bloomington, Illinois 61704 309/663-8435, 309/663-1571 fax</p>	USER NAME = dmeyer	DESIGNED - JJO	REVISED -	<p align="center"><b>STATE OF ILLINOIS</b> <b>DEPARTMENT OF TRANSPORTATION</b></p>	<p align="center"><b>RIVER PARK DRIVE CONNECTOR</b> <b>DRAINAGE PLAN &amp; PROFILE</b></p>				F.A.P. RT.E. = 788	SECTION = 520-1-2	COUNTY = ST. CLAIR	TOTAL SHEETS = 142	SHEET NO. = 44
	PLOT SCALE = 48.0000' / in.	CHECKED - PJM	REVISED -		SCALE:	SHEET NO.	OF SHEETS	STA.	TO STA.	<p align="center"><b>CONTRACT NO. 76850</b></p>			
	PLOT DATE = 3/21/2013	DATE = 03/20/13	REVISED -			<p align="center">ILLINOIS FED. AID PROJECT</p>							