




- LEGEND**
- EXISTING PAVEMENT
  - PROPOSED PAVEMENT
  - EXISTING ELECTRICAL CABLE
  - EXISTING ELECTRICAL DUCT
  - EXISTING SPLICE CAN
  - EXISTING STAKE MOUNTED TAXIWAY LIGHT
  - EXISTING BASE MOUNTED TAXIWAY LIGHT
  - EXISTING BASE MOUNTED RUNWAY LIGHT
  - EXISTING BASE MOUNTED THRESHOLD LIGHT
  - PROPOSED 1/C, #8 5KV CABLE IN UNIT DUCT
  - PROPOSED 1/C, #8 5KV CABLE IN EXISTING UNIT DUCT
  - PROPOSED CONCRETE ENCASED DUCT
  - PROPOSED STAKE MOUNTED TAXIWAY LIGHT
  - PROPOSED BASE MOUNTED TAXIWAY LIGHT

THE LOCATION, SIZE AND TYPE OF MATERIAL OF EXISTING UNDERGROUND UTILITIES INDICATED ON THE PLANS IS NOT REPRESENTED AS BEING ACCURATE, SUFFICIENT OR COMPLETE. IT SHALL BE THE CONTRACTOR'S RESPONSIBILITY TO DETERMINE THE ACTUAL LOCATION OF ALL SUCH FACILITIES, INCLUDING SERVICE CONNECTIONS TO UNDERGROUND UTILITIES. PRIOR TO CONSTRUCTION, THE CONTRACTOR SHALL NOTIFY THE UTILITY COMPANIES OF HIS OPERATIONAL PLANS AND SHALL OBTAIN FROM THE RESPECTIVE UTILITY COMPANIES DETAILED INFORMATION AND ASSISTANCE RELATIVE TO THE LOCATION OF THEIR FACILITIES AND THE WORKING SCHEDULE OF THE COMPANIES FOR REMOVAL OR ADJUSTMENT WHERE REQUIRED. IN THE EVENT AN UNEXPECTED UTILITY INTERFERENCE IS ENCOUNTERED DURING CONSTRUCTION, THE CONTRACTOR SHALL IMMEDIATELY NOTIFY THE UTILITY COMPANY OF JURISDICTION. THE ENGINEER SHALL ALSO BE IMMEDIATELY NOTIFIED. ANY SUCH MAINS AND SERVICES SHALL BE RESTORED TO SERVICE AT ONCE AND PAID FOR BY THE CONTRACTOR AT NO ADDITIONAL COST TO THE CONTRACT.

CALL J.U.L.I.E. FOR UTILITY INFORMATION AT 1-800-892-0123.

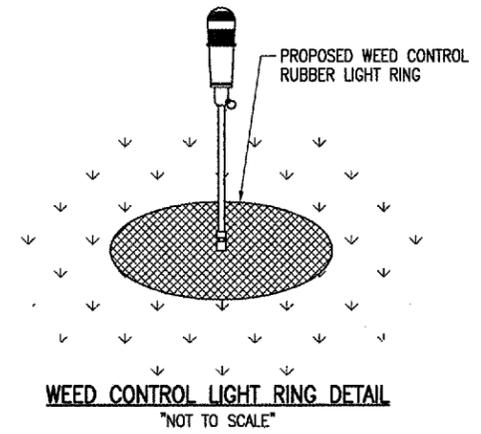

**WEED CONTROL LIGHT RING NOTE**  
ALL PROPOSED LIGHTS SHALL HAVE A WEED CONTROL LIGHT RING PLACED AT ITS BASE. SEE SPECIAL PROVISIONS FOR ITEM AR800449.

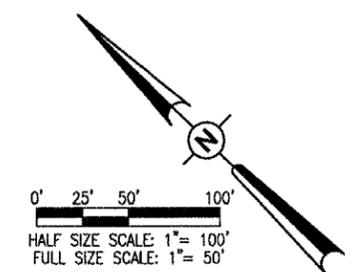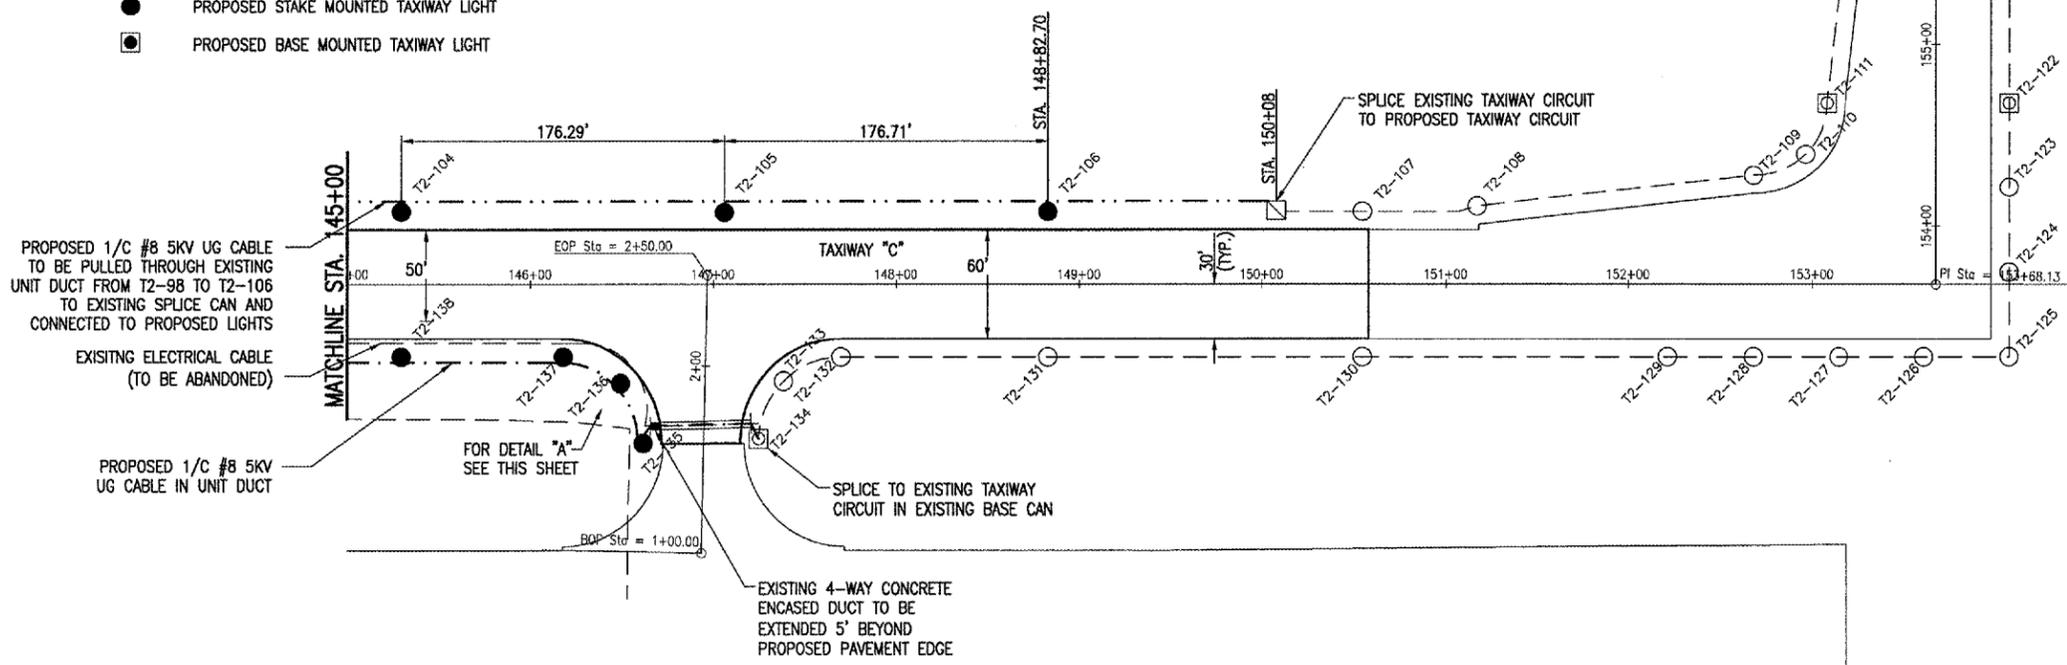

REVISION	DATE	BY

QUINCY REGIONAL AIRPORT  
BALDWIN FIELD  
ADAMS COUNTY, ILLINOIS

IL PROJ.: UIN-3690 A.I.P. PROJ.: 3-17-0085-B1

HEL Project No.: 82407XVD_0100	DATE: 03/14/07
Filename: R-142ELE.DWG	MLH 03/14/07
Scale: 1" = 50'	MLH 03/16/07
Date: 03/14/07	MLH 03/16/07
LAYOUT	JDW 03/19/07
DRAWN	
REVIEWED	



REALIGN, WIDEN AND REHABILITATE TAXIWAY "C" - PHASE 2  
PROPOSED ELECTRICAL PLAN  
STA. 145+00 TO STA. 153+68.13

MAY 09, 2007 2:14 PM MLH I:\AIRPORTS\QUINCY\82407XVD\AIRPORT\ SHEETS\R-142ELE.DWG - 145+00 TO 151+00