


NOTES:

- EXISTING PUMP STATION SHALL REMAIN OPERATIONAL UNTIL NEW PUMP STATION IS OPERATIONAL. COMED IS TO PROVIDE A TEMPORARY SERVICE TO THE EXISTING PUMP STATION PRIOR TO REMOVING THE EXISTING SERVICE. CONTRACTOR IS RESPONSIBLE FOR COORDONATING WITH COMED SERVICE DISRUPTIONS SUCH THAT ONE SERVICE IS IN CONSTANT OPERATION. CONTRACTOR SHALL INITIATE CANCELLATION OF EXISTING SERVICE, AND ONCE THE NEW PUMP STATION IS COMMISSIONED ENSURE THAT THE PROCESS IS COMPLETED INCLUDING TERMINATING BILLING AND INVOICES FOR ENERGY CHARGES. THE FOLLOWING CONSTRAINT SHALL BE FOLLOWED:
THE TEMPORARY COMED TRANSFORMERS, POLES AND SERVICE EXTENSION SHALL BE INSTALLED PRIOR TO DISCONNECTION OF THE EXISTING COMED EQUIPMENT.
- SEE THE RIGHT OF WAY PLAT AND S.U.E. CIVIL SHEETS FOR ADDITIONAL INFORMATION ON R.O.W. AND UNDERGROUND UTILITIES.

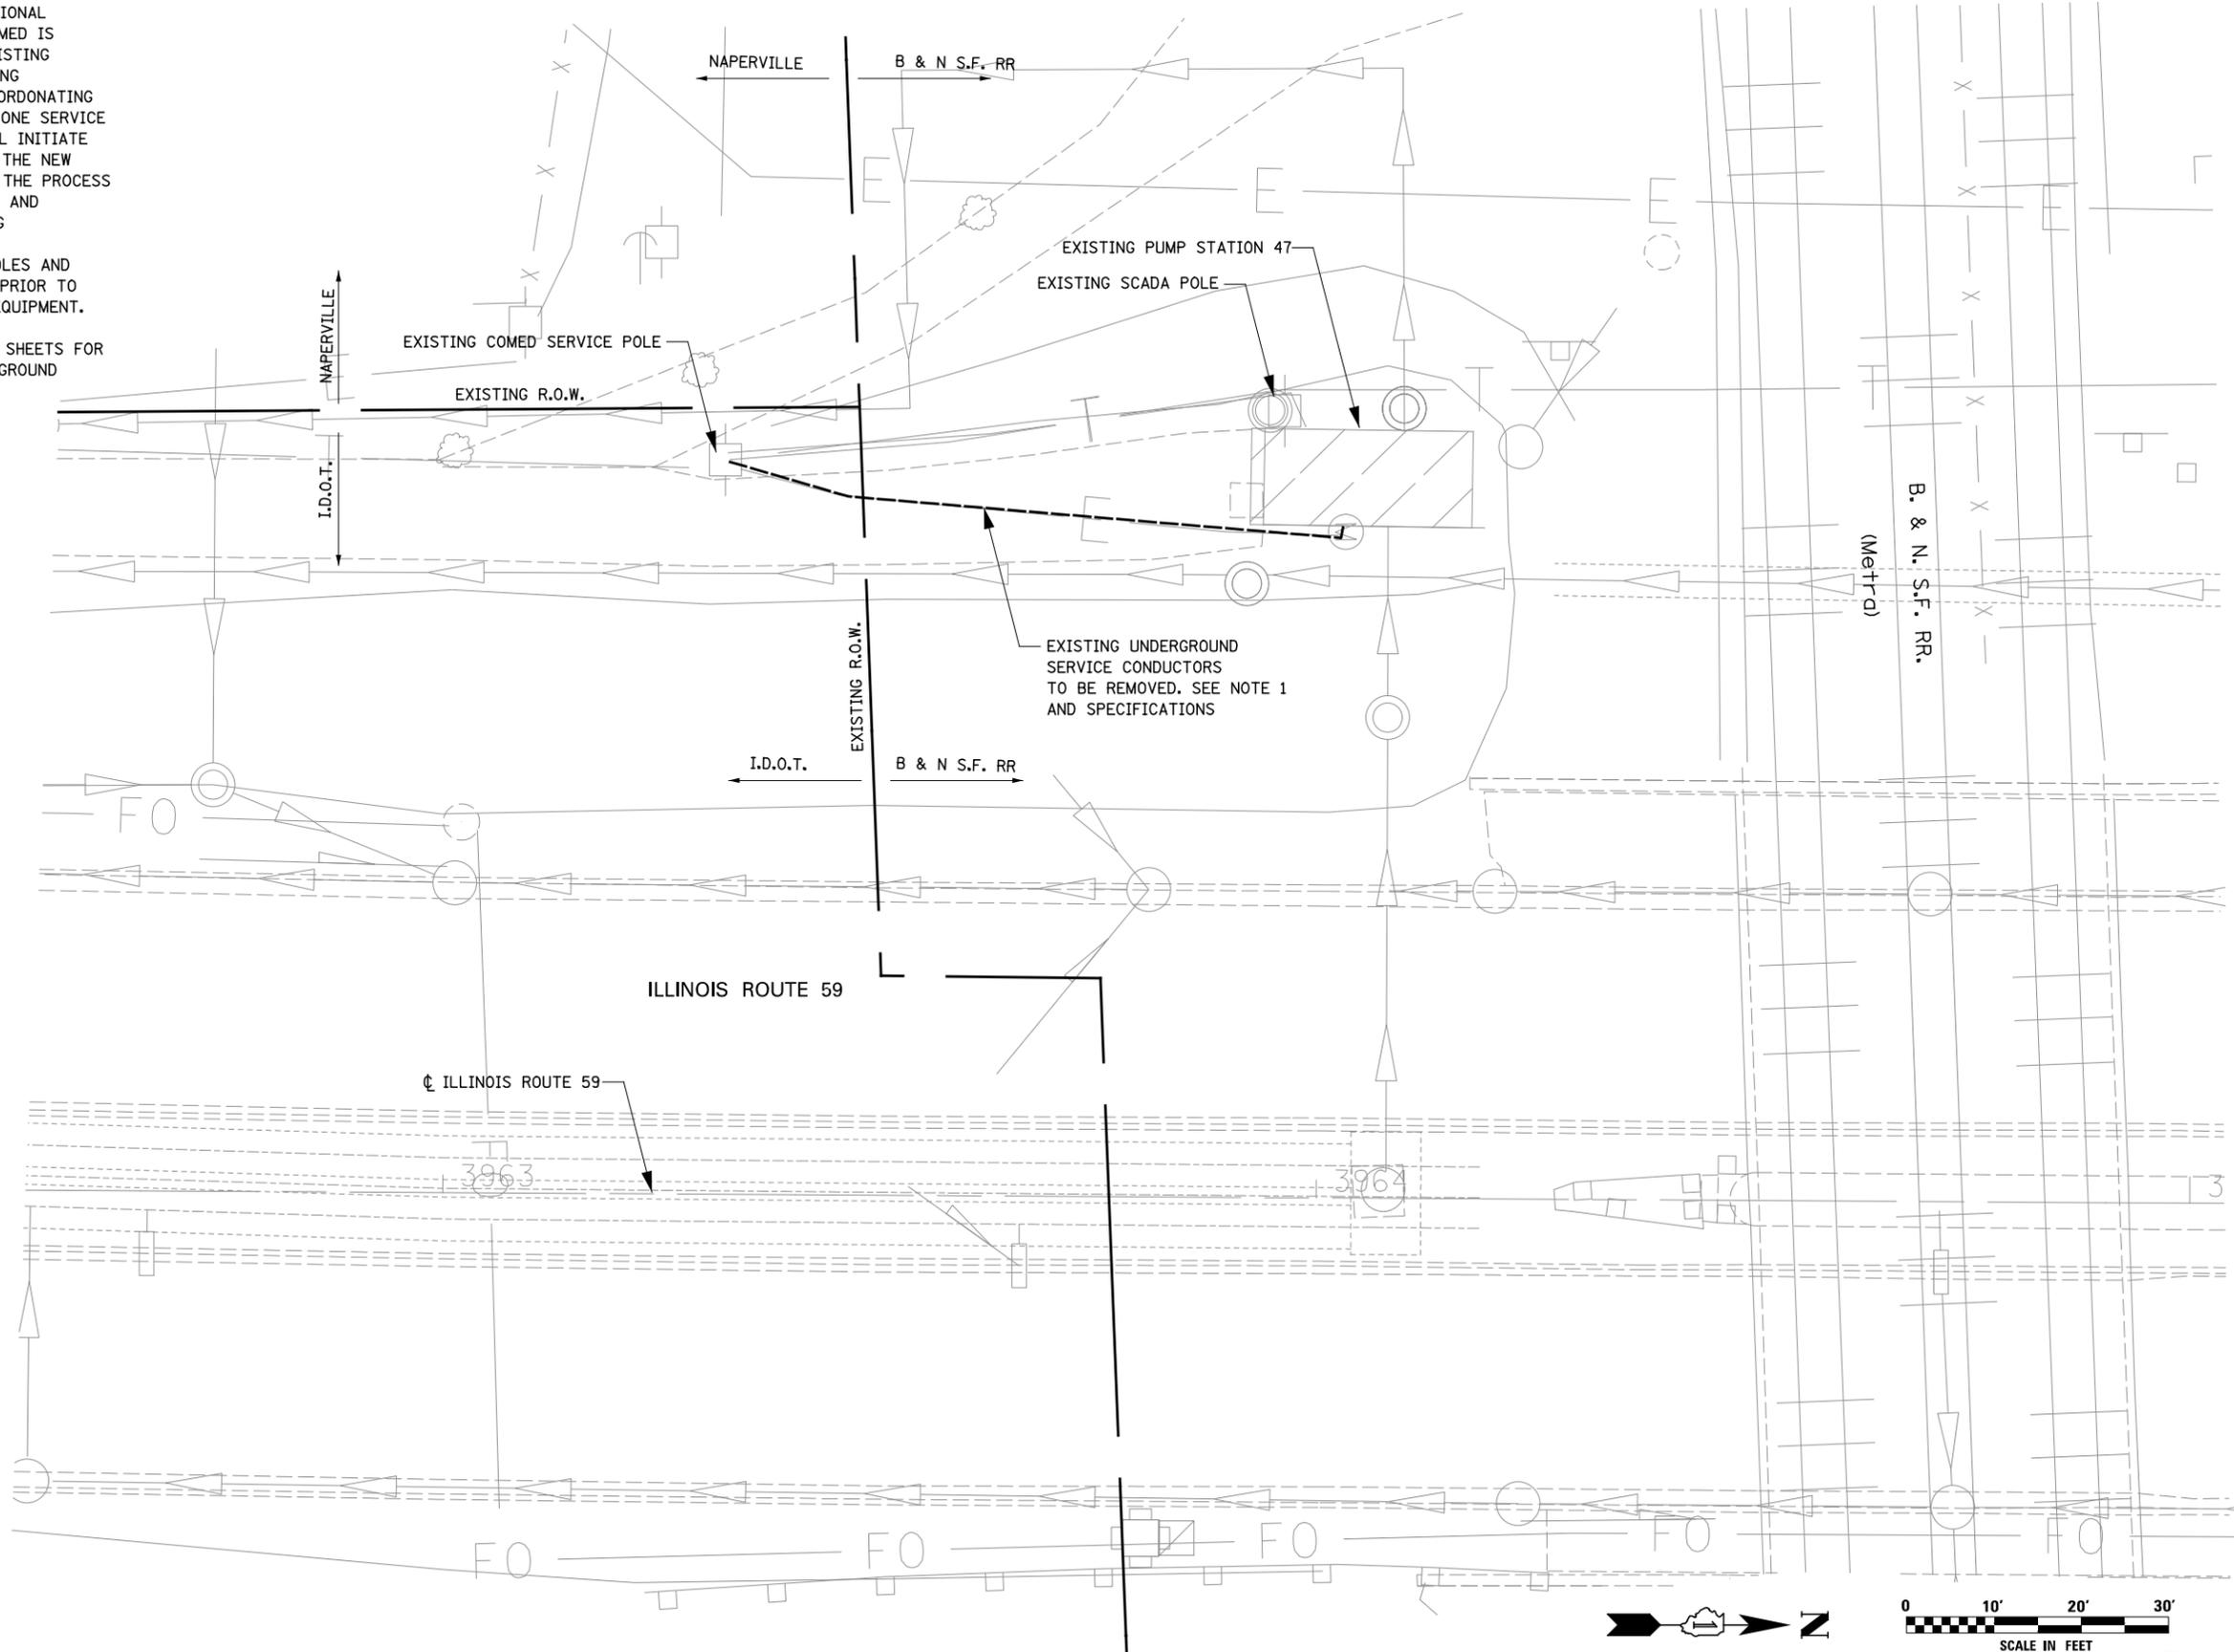

E4

KNIGHT Engineers & Architects	USER NAME = *USER*	DESIGNED - MCP	REVISED -	STATE OF ILLINOIS DEPARTMENT OF TRANSPORTATION	PUMP STATION EXISTING ELECTRICAL SITE PLAN			F.A.P. RTE.	SECTION	COUNTY	TOTAL SHEETS	SHEET NO.
	PLOT SCALE = *SCALE*	DRAWN - MLB	REVISED -		338/IL 59	2011-035-I	DUPAGE	181	160			
	PLOT DATE = *DATE*	CHECKED - MCP	REVISED -		SCALE: SHEET NO. OF SHEETS STA. 3942+00 TO STA. 3969+00			CONTRACT NO. 60P41				
	DATE 03-22-2012	REVISED -		ILLINOIS FED. AID PROJECT								