



3 INTERMEDIATE FLOOR (-2) LIGHTING/RECEPTACLE PLAN - EL:684.00
SCALE: 1/4" = 1'-0"

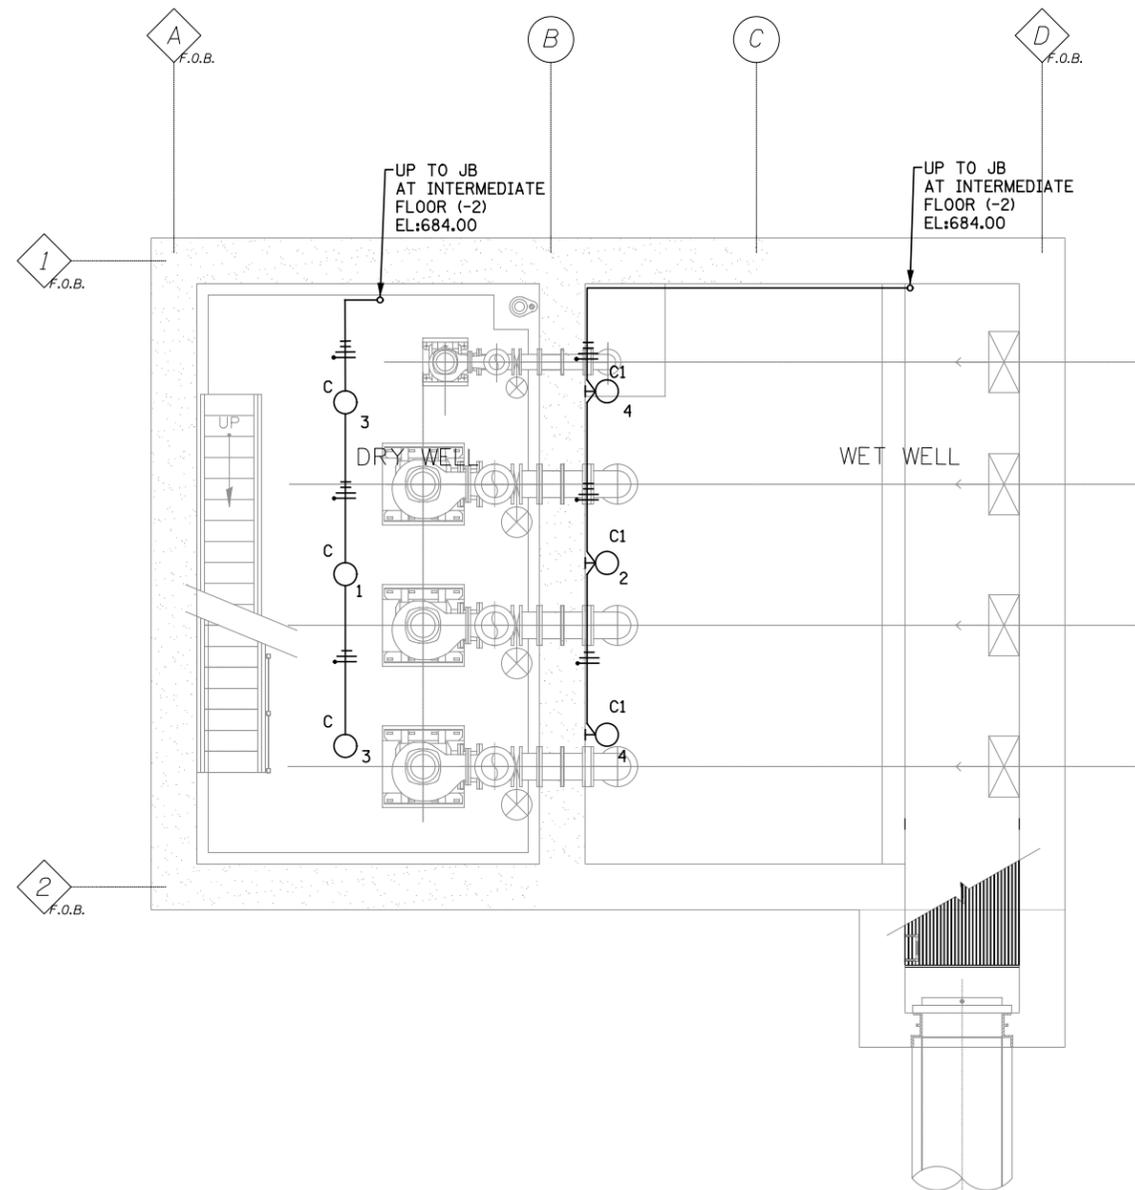

4 WELL LEVEL FLOOR (-3) LIGHTING/RECEPTACLE PLAN - EL:673.00
SCALE: 1/4" = 1'-0"
- WET EL:671.50

NOTES:

 1. SEE SHT. E11 FOR LIGHTING PANEL SCHEDULE AND LIGHTING FIXTURE SCHEDULE.
2. ELECTRICAL INSTALLATION AND EQUIPMENT WITHIN ENTIRE WET AND DRY WELL AREA SHALL BE PER N.E.C. CLASS I DIV. 2.



SCALE IN FEET

E7A

KNIGHT Engineers & Architects	USER NAME = *USER*	DESIGNED - MCP	REVISED -	STATE OF ILLINOIS DEPARTMENT OF TRANSPORTATION	PUMP STATION 47 LIGHTING AND RECEPTACLE PLANS				F.A.P. RTE.	SECTION	COUNTY	TOTAL SHEETS	SHEET NO.
	PLOT SCALE = *SCALE*	DRAWN - MLB	REVISED -						338/IL 59	2011-035-I	DUPAGE	181	168
PLOT DATE = *DATE*	CHECKED - MCP	REVISED -	DATE 03-22-2012	REVISED -	SCALE:	SHEET NO.	OF SHEETS	STA.	TO STA.	CONTRACT NO. 60P41			
										ILLINOIS FED. AID PROJECT			