




CONTRACT NO.			
F.A. RTE.	SECTION	COUNTY	TOTAL SHEET NO.
STA.	TO STA.		
FED. ROAD DIST. NO.	ILLINOIS	FED. AID PROJECT	

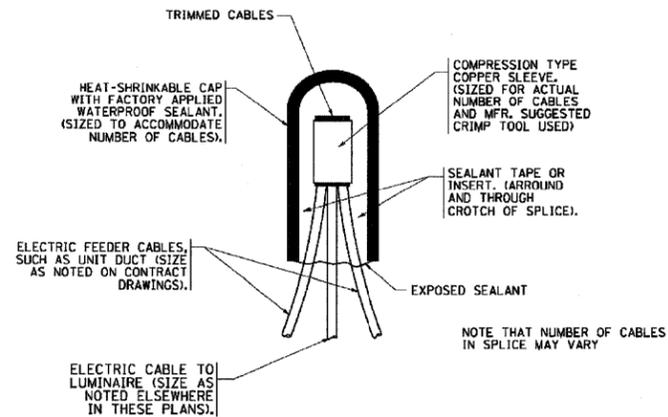

**TYPICAL SPLICE DETAIL**  
N.T.S.

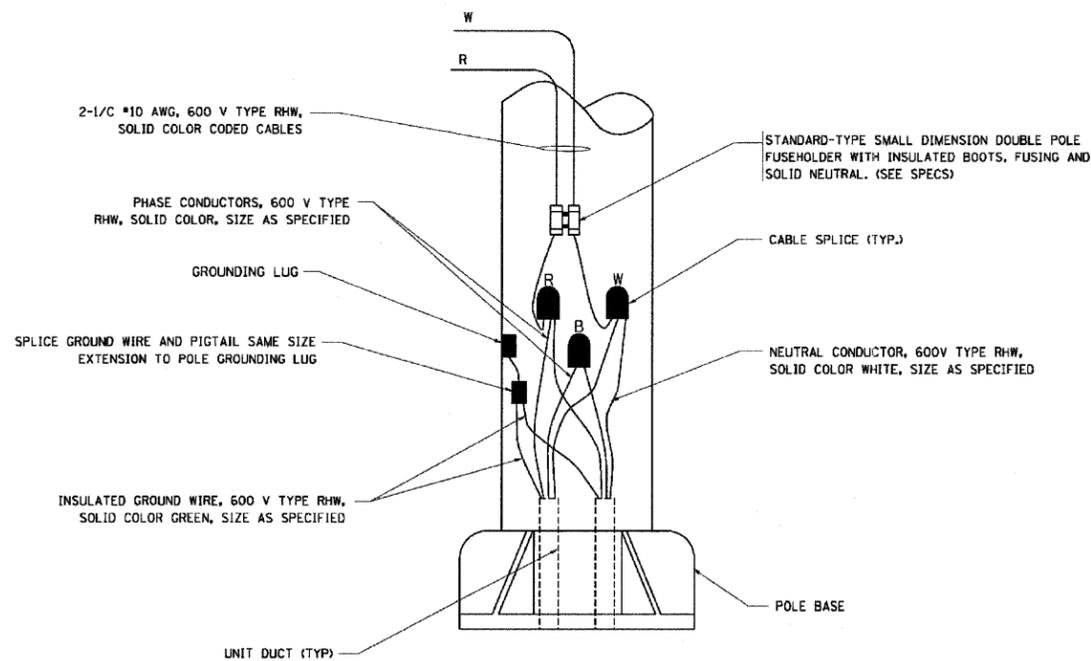

**POLE WIRING DETAIL**  
N.T.S.

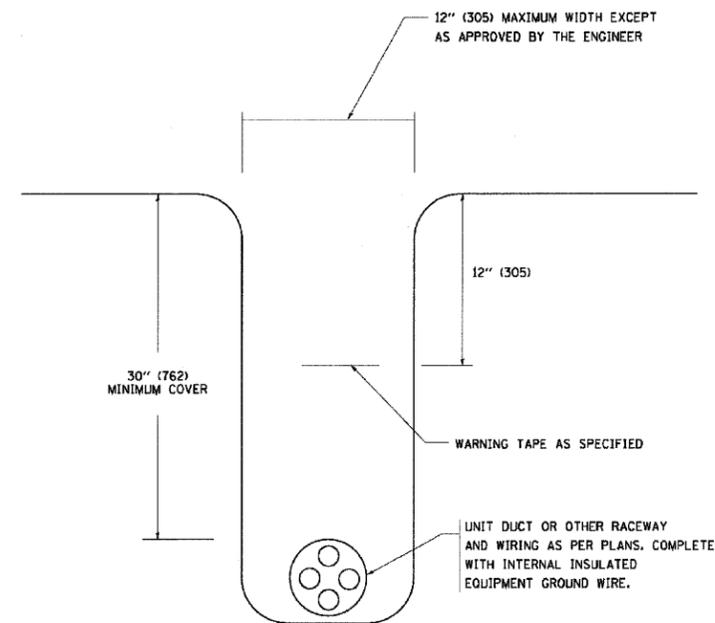

**TYPICAL WIRING IN TRENCH DETAIL**  
N.T.S.

PLOT DATE = 4/18/2007  
 FILE NAME = K:\GIS\155\155-dgn\155-dgn.dgn  
 PLOT SCALE = 1/8" = 1'-0"  
 USER = user

REVISIONS	
NAME	DATE
	08/08/03

ILLINOIS DEPARTMENT OF TRANSPORTATION

**MISC. ELECTRICAL DETAILS**  
SHEET A

SCALE: VERT. NONE  
HORIZ.

DRAWN BY  
CHECKED BY  
BE-702

**SINGH** 300 W. ADAMS ST.  
CHICAGO, IL 60606  
SINGH & ASSOCIATES, INC. TEL: (312) 629-0240  
CONSULTING ENGINEERS FAX: (312) 629-8449

USER NAME = #USER#  
DESIGNED - MK  
DRAWN - YJ  
CHECKED - GR  
DATE - 3-25-2011

REVISOR -  
REVISOR -  
REVISOR -  
REVISOR -

**STATE OF ILLINOIS**  
**DEPARTMENT OF TRANSPORTATION**

**CENTRAL AVENUE OVER I-55**  
**IDOT LIGHTING STANDARD DETAILS**

SCALE: 1" = 20' SHEET NO. OF SHEETS STA. TO STA.

F.A. RTE.	SECTION	COUNTY	TOTAL SHEETS	SHEET NO.
55	9(H, HB & SB)R-1	COOK	741	223
CONTRACT NO. 60999				
FED. ROAD DIST. NO.	ILLINOIS	FED. AID PROJECT		