

STATE OF ILLINOIS)
 COUNTY OF COOK) S.S.

UTILITY(IES) SHOWN HEREON HAVE BEEN INVESTIGATED BY ASE IN ACCORDANCE WITH SUE INDUSTRY STANDARDS QUALITY LEVEL B (QLB). ALL OTHER INFORMATION SHOWN HAS BEEN PROVIDED BY OTHERS.

FIELD WORK WAS PERFORMED BETWEEN THE 17TH DAY OF NOVEMBER, 2009 AND 12TH DAY OF AUGUST, 2010 AND BETWEEN THE 23RD DAY OF MAY, 2011 AND THE 20TH DAY OF JULY, 2011.

IN WITNESS WHEREOF, I HAVE HEREUNTO SET MY HAND AND SEAL THIS 29TH DAY OF JULY A.D., 2011. CHICAGO, IL.

AT&T UNDERGROUND TELEPHONE LINE
 SUE QUALITY LEVEL B


NICOR UNDERGROUND GAS LINES
 SUE QUALITY LEVEL B

LEGEND

- T — EXISTING UNDERGROUND TELEPHONE
- W — EXISTING UNDERGROUND WATER
- E — EXISTING UNDERGROUND ELECTRIC
- G — EXISTING UNDERGROUND GAS
- CTV — EXISTING UNDERGROUND CABLE TV
- EOGI END OF GEOPHYSICAL INFORMATION



Steven M. Rienks
 STEVEN M. RIENKS - ILLINOIS PROFESSIONAL ENGINEER NUMBER 62-044619
 MY LICENSE EXPIRES 11/30/2011

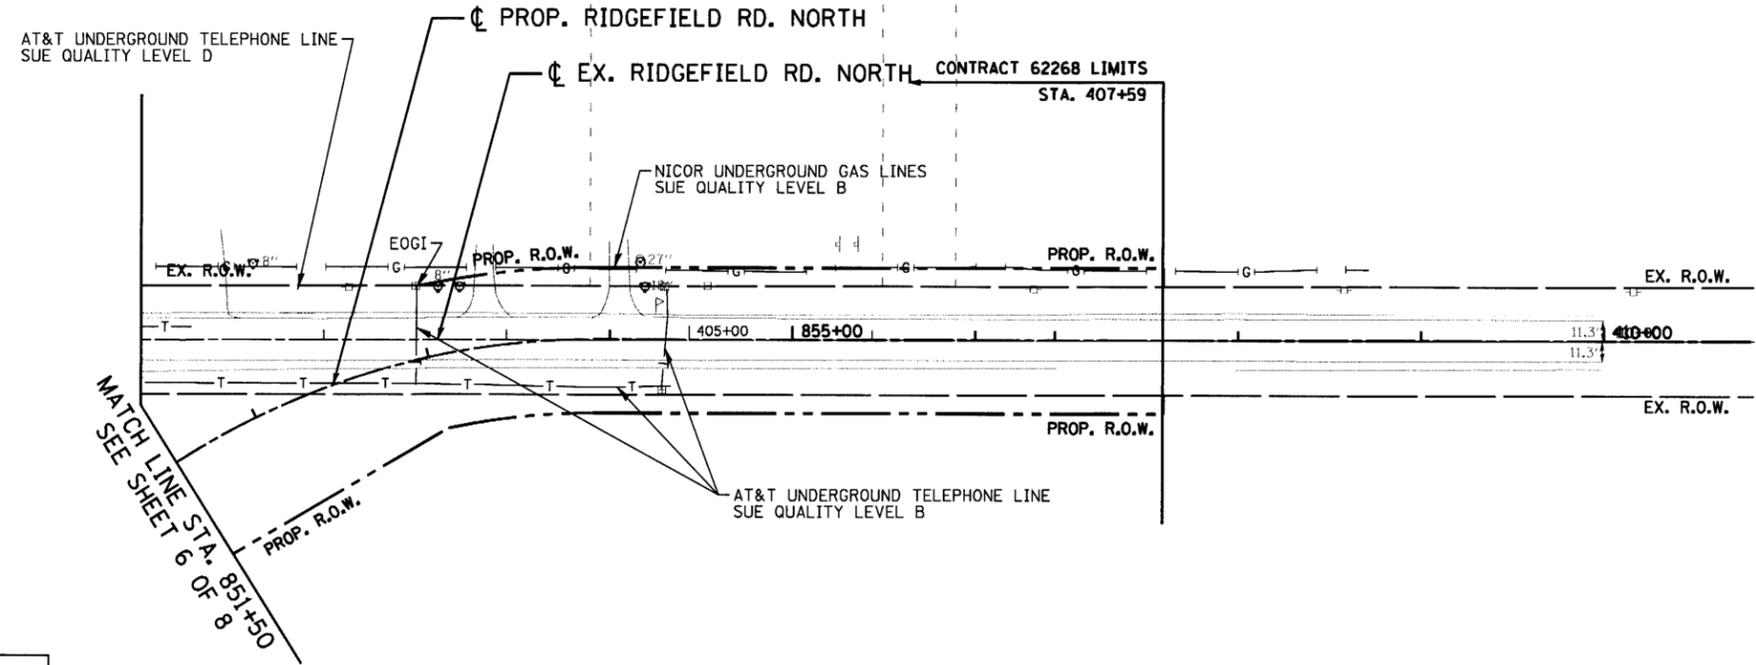

AT&T UNDERGROUND TELEPHONE LINE
 SUE QUALITY LEVEL D

MATCH LINE STA. 851+50
 SEE SHEET 6 OF 8

NOTES:

1. HORIZONTAL CONTROL, VERTICAL CONTROL, CENTERLINE ALIGNMENT, TOPOGRAPHIC FEATURES, AND ALL UTILITY LINE WORK (EXCEPTING SUE QUALITY LEVEL B DESIGNATIONS) WERE SUPPLIED BY ILLINOIS DEPARTMENT OF TRANSPORTATION.

AMERICAN
 SURVEYING & ENGINEERING, P.C.
 SURVEYORS - ENGINEERS
 GEODESISTS - MAPPING SCIENTISTS
 Chicago 312-277-2000 / Fax 312-277-2002
 Dixon 815-288-6231 / Fax 815-288-6277
 Aurora 603-897-4105 / Fax 630-897-4121
 Illinois Professional Design Firm No. 184-003192

FILE NAME = Utl808.dgn	USER NAME = **User**	DESIGNED -	REVISED - 7-22-11 ADD. INFORMATION
		DRAWN -	REVISED -
		CHECKED -	REVISED -
		DATE - >DATE	REVISED -

STATE OF ILLINOIS
 DEPARTMENT OF TRANSPORTATION
 U.S. ROUTE 14

UTILITY PLANS
 BY S.U.E.
 LILY POND & RIDGEFIELD RD.
 SCALE: 1"=50'
 SHEET NO. 8 OF 8 SHEETS STA. TO STA.

F.A.P. RTE.	SECTION	COUNTY	TOTAL SHEETS	SHEET NO.
305	27R-2	MCHENRY		
CONTRACT NO. 62268				

FED. ROAD DIST. NO. 1 ILLINOIS FED. AID PROJECT