


NOTES:

1. ALL DIMENSIONS INCLUDING BUT NOT LIMITED TO EXISTING FACIA STRUCTURE, BRACKET SPACING, AND RAILING SPACING TO BE FIELD VERIFIED BY CONTRACTOR.
2. EACH GATEWAY MONUMENT SIGN PANEL TO BE CENTERED BETWEEN THE BRACKETS OF THE EXISTING FACIA STRUCTURE.
3. SEE ELECTRICAL PLAN FOR LIGHTING AND ELECTRICAL MODIFICATIONS.
4. CLEANING AND PAINTING STRUCTURAL STEEL, AT THE LOCATION ENUMERATED SHALL INCLUDE BUT IS NOT LIMITED TO COLUMNS, PIER BENTS, BASE PLATES, BRACKETS, FASCIA BEAM, AND CONNECTIONS. THE BEAMS COMPRISING THE MAIN SUPERSTRUCTURE SHALL NOT BE PAINTED.


LEGEND:

 EXISTING SURFACE TO BE PAINTED

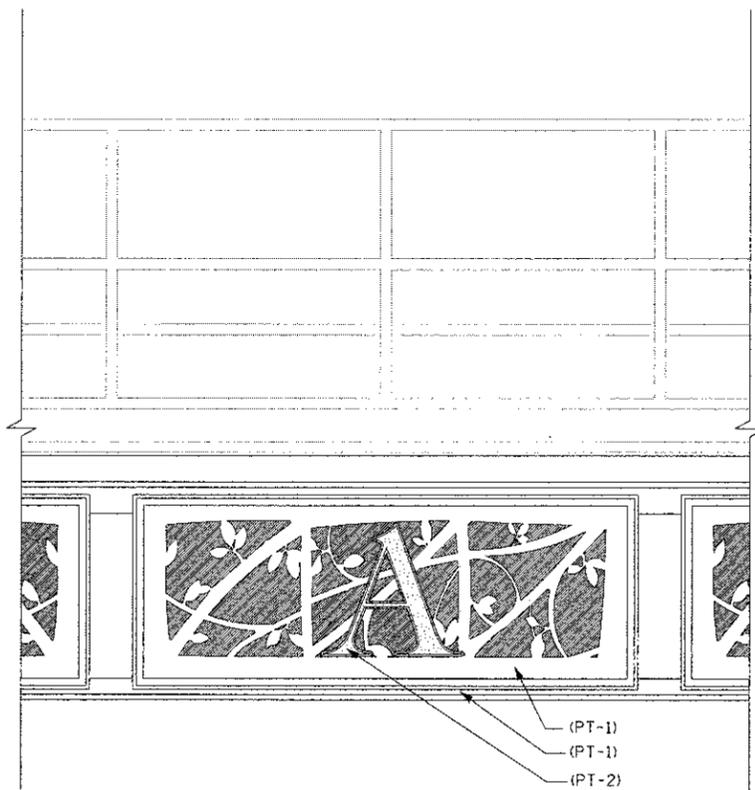


ENLARGED FASCIA DETAIL

NOT TO SCALE

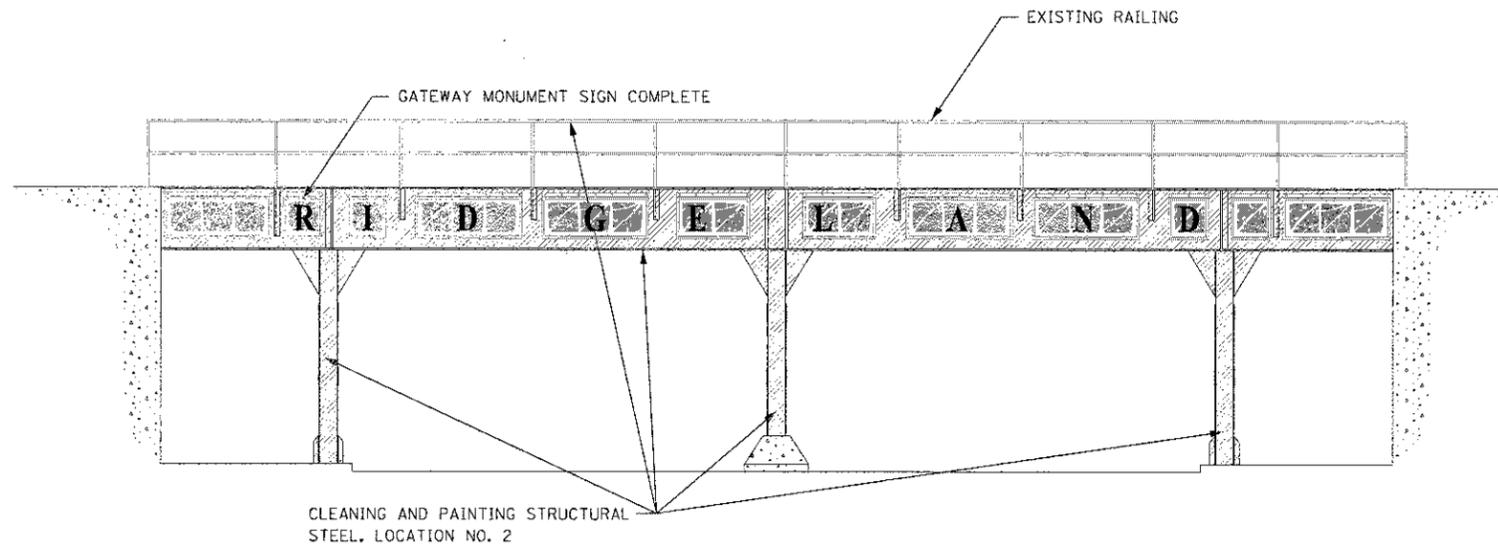

RIDGELAND VIADUCT NORTH ELEVATION

NOTE: ONE ILLUMILINE 36 IP OPTIC 30 RGB SHALL BE PROVIDED FOR EACH PANEL OF THE GATEWAY MONUMENT SIGN COMPLETE. THE FIXTURE, CONDUIT, ELECTRIC CABLE AND ANY OTHER MATERIALS NEEDED TO INSTALL EACH ILLUMILINE 36 IP OPTIC 30 RGB SHALL BE INCLUDED IN THE UNIT PRICE OF GATEWAY MONUMENT SIGN COMPLETE.

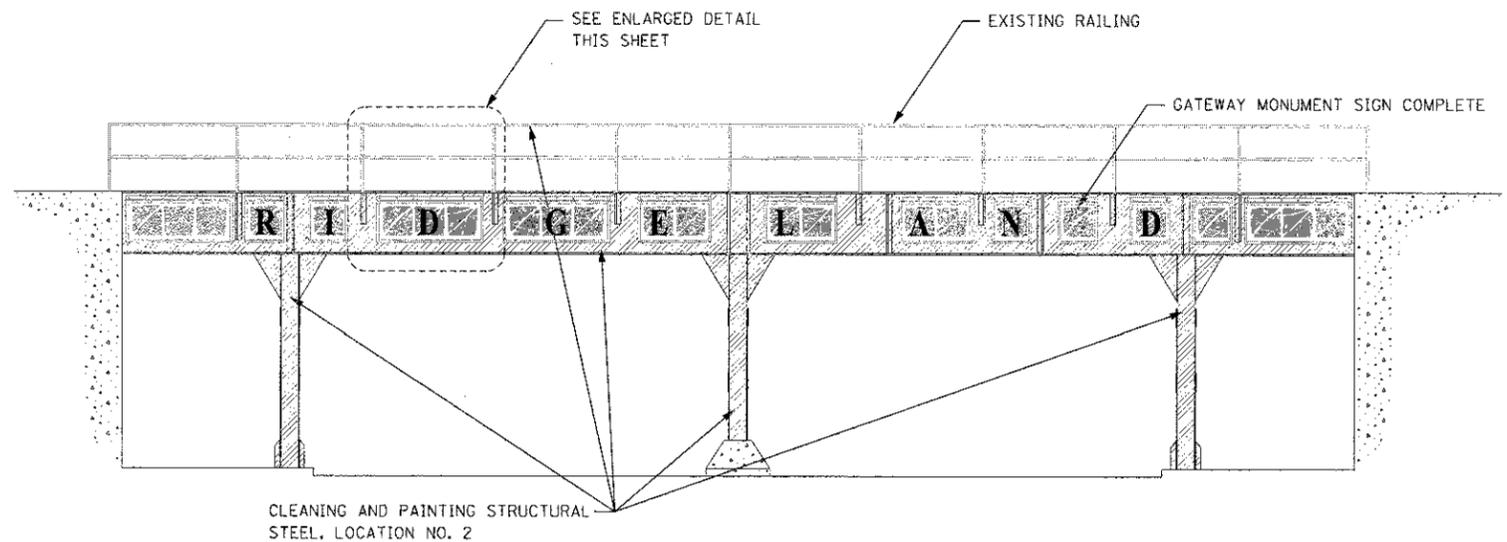

RIDGELAND VIADUCT SOUTH ELEVATION

NOTE: ONE ILLUMILINE 36 IP OPTIC 30 RGB SHALL BE PROVIDED FOR EACH PANEL OF THE GATEWAY MONUMENT SIGN COMPLETE. THE FIXTURE, CONDUIT, ELECTRIC CABLE AND ANY OTHER MATERIALS NEEDED TO INSTALL EACH ILLUMILINE 36 IP OPTIC 30 RGB SHALL BE INCLUDED IN THE UNIT PRICE OF GATEWAY MONUMENT SIGN COMPLETE.



FILE NAME = S:\JUL\1700-6799\6784\B12\Micro\ACADD_Sheets\16163722-1h.rvt.ridgeland-elev.dgn

SA
STRAND
ASSOCIATES*

1170 SOUTH HOUBOLT ROAD
JOLIET, ILLINOIS 60431
(815) 744-4200

USER NAME = amanda.j
DESIGNED - JDM
DRAWN - JKP
CHECKED - MTC
DATE - 05-07-2012

REVISIONS:
REVISION NO. | DESCRIPTION | DATE
1 | | |
2 | | |

STATE OF ILLINOIS
DEPARTMENT OF TRANSPORTATION

RIDGELAND AVENUE VIADUCT ELEVATIONS

SCALE: AS SHOWN SHEET NO. OF SHEETS STA. TO STA.

F.A.U. RTE.	SECTION	COUNTY	TOTAL SHEETS	SHEET NO.
2783	11-00253-00-LS	COOK	24	13
CONTRACT NO. 63722			ILLINOIS FED. AID PROJECT	