


F.A. RTE.	SECTION	COUNTY	TOTAL SHEETS	SHEET NO.
	03-00026-00-PK	MADISON	38	27

FEDERAL AID PROJECT

KEYED NOTES:

- 1 1HW HY-1 AND 1 CW HY-1, PROVIDE SHUT OFF VALVES ACCESSIBLE BY ACCESS PANEL TO SHUT OFF HY-1'S.
- 2 PROVIDE SHUT OFF VALVE ACCESSIBLE BY ACCESS PANEL TO SHUT OFF DF-1.
- 3 2" VENT, 1 1/2" WATER CAPPED FOR FUTURE EXTENSION IN PHASE 2A.

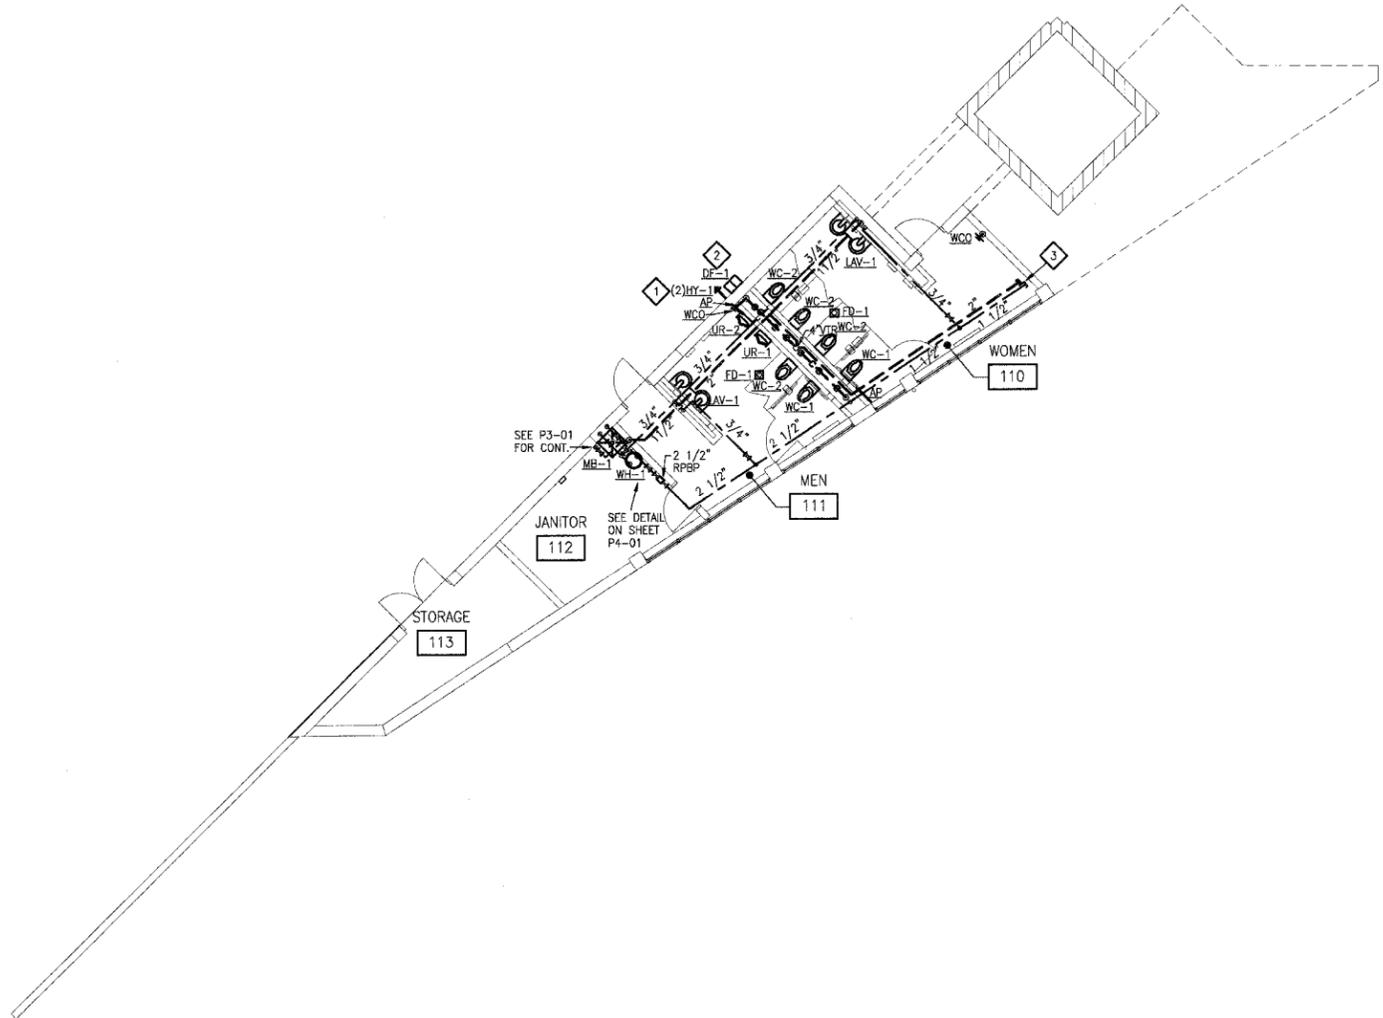

**A** FIRST FLOOR PLAN-PLUMBING  
1/8"=1'-0"

211 N. Broadway  
Suite 1000  
St. Louis, MO 63102  
(314) 241-0100  
FAX (314) 241-0105



**PHASE 2B**  
**LEWIS AND CLARK MEMORIAL TOWER**  
**VILLAGE OF HARTFORD, ILLINOIS**  
HARTFORD, ILLINOIS 62049

SHEET TITLE:  
**FIRST FLOOR PLAN-  
PLUMBING**

REV. NO.	REMARKS	DATE

KENNEDY PROJECT NO  
KAI# 10-02048

ISSUE DATE  
12-JULY-05

SHEET NO  
**P3-02**