

211 N. Broadway  
Suite 1000  
St. Louis, MO 63102  
(314) 241-0100  
FAX (314) 241-0125

**KAI**

**PHASE 2B  
LEWIS AND CLARK MEMORIAL TOWER  
VILLAGE OF HARTFORD, ILLINOIS  
HARTFORD, ILLINOIS 62049**

SHEET TITLE:  
**ONE LINE DIAGRAM**

REV. NO.	REMARKS	DATE


KENNEDY PROJECT NO  
KAI# 10-02048

ISSUE DATE  
12-JULY-05

SHEET NO

**E5-01**

© 2005 KENNEDY ASSOCIATES INCORPORATED

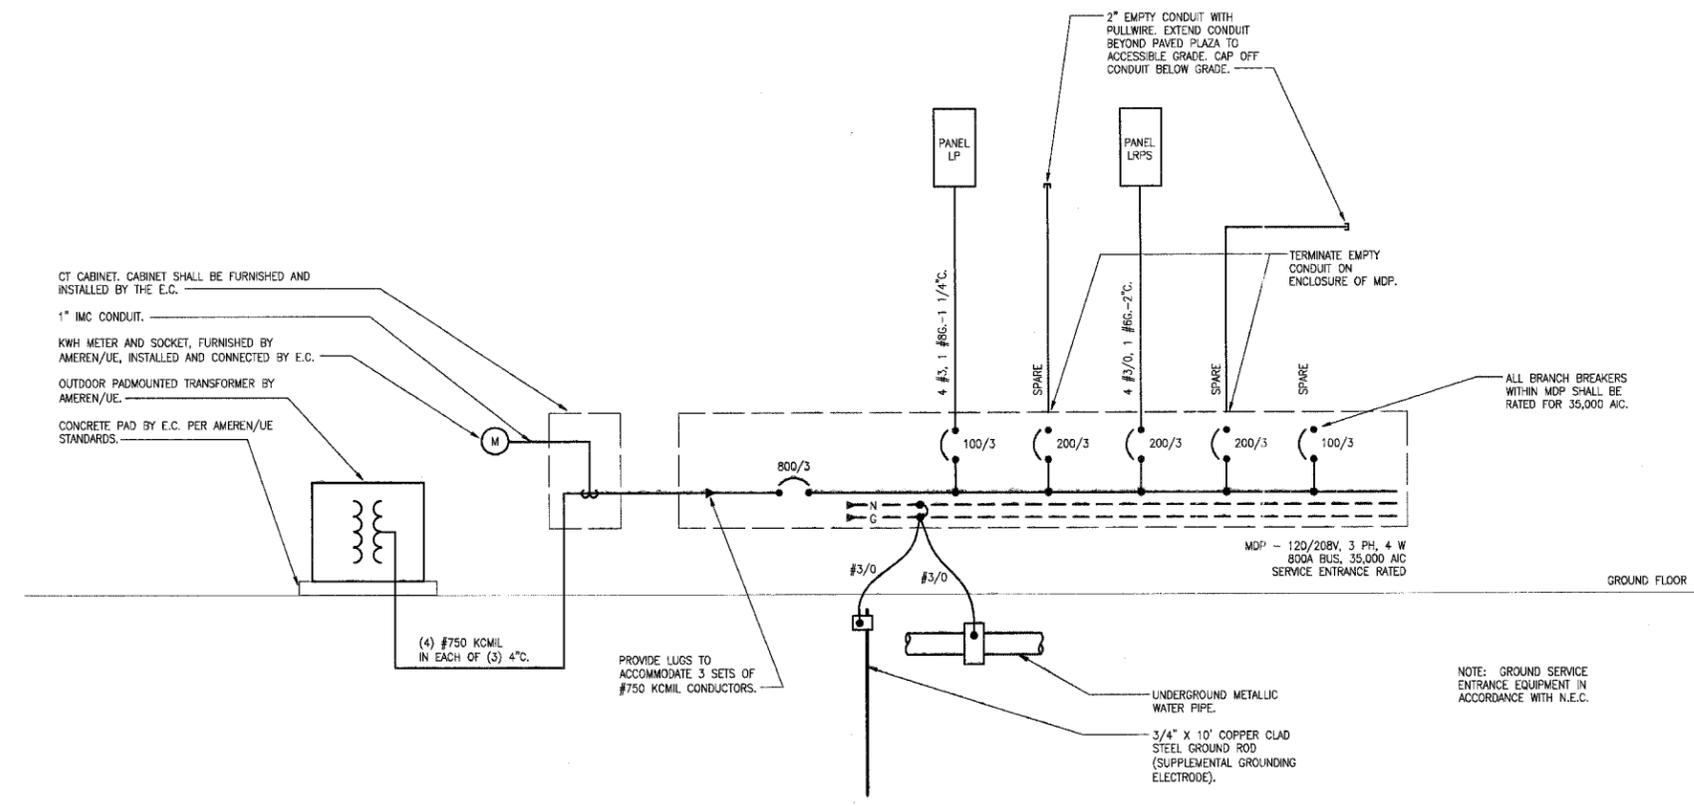

**A ONE LINE DIAGRAM**  
NO SCALE