


J:\265\dgn\Sheets\160133-sht-light-04.dgn
 6/26/2012 11:26:32 AM

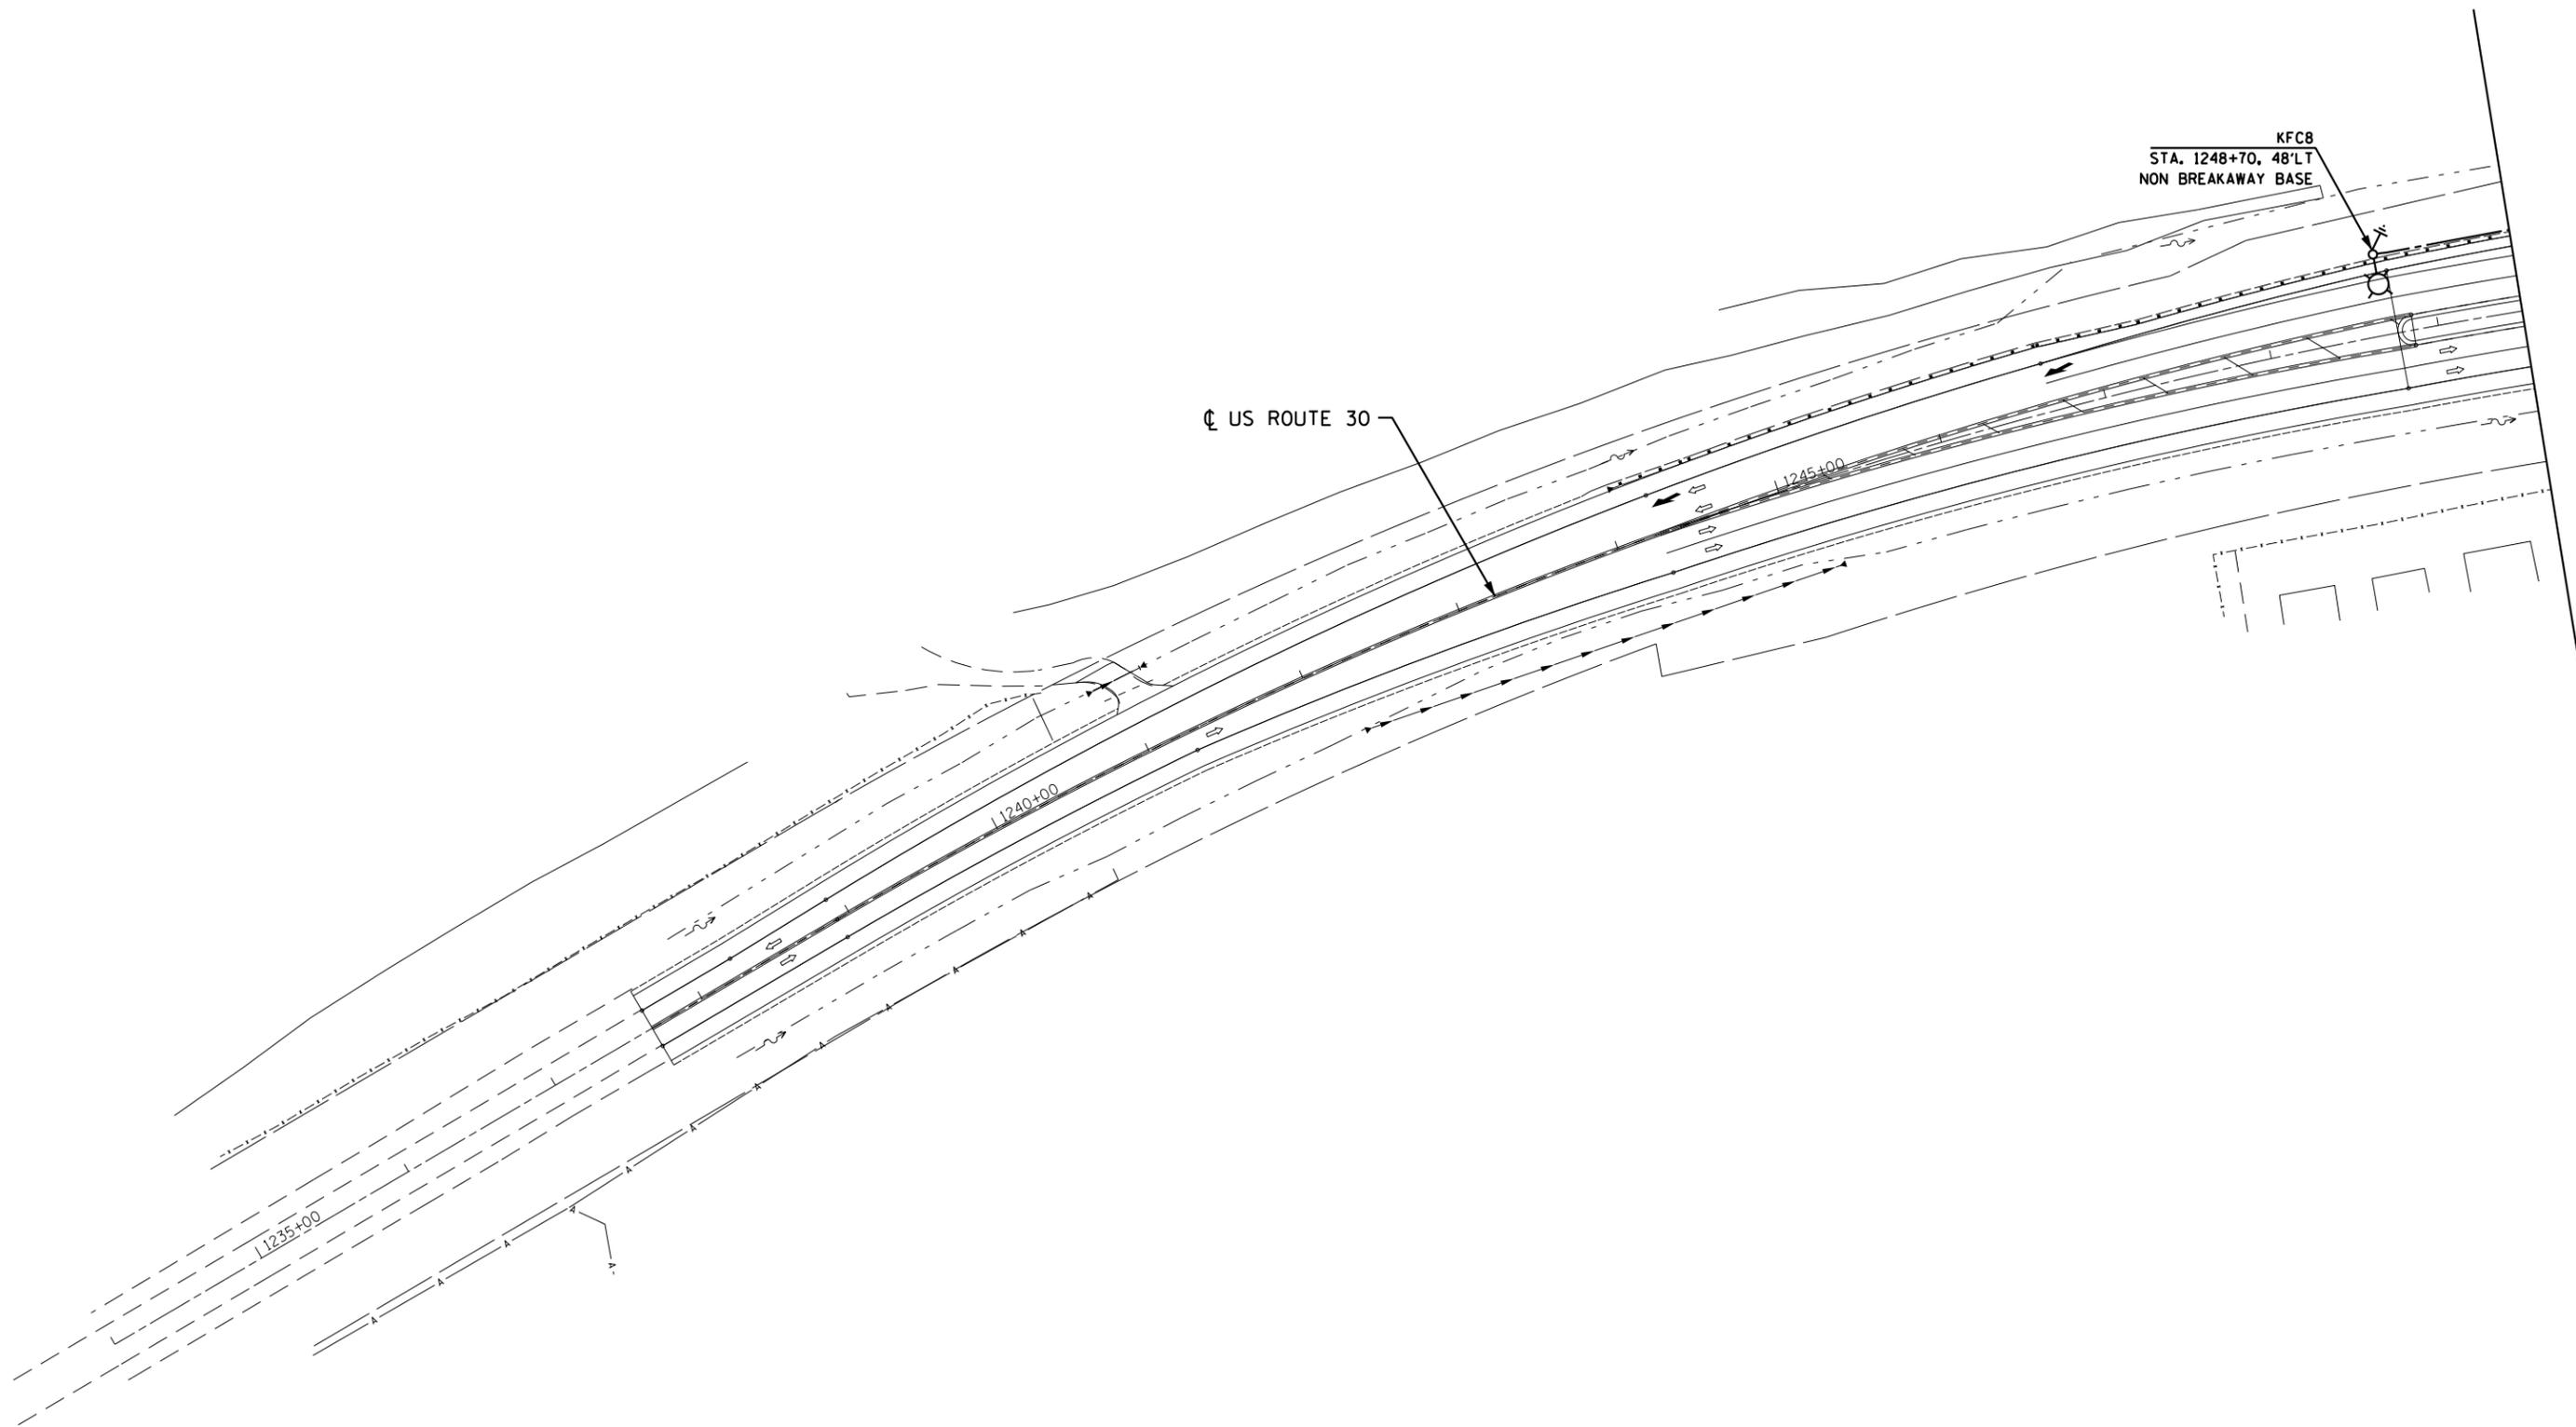

SINGH
 CONSULTING ENGINEERS
 www.singhinc.com

USER NAME = kprejapati	DESIGNED - KP	REVISED -
	DRAWN - WC/RP	REVISED -
PLOT SCALE = 100.0000' / in.	CHECKED - GR	REVISED -
PLOT DATE = 6/26/2012	DATE - 06/15/2012	REVISED -

STATE OF ILLINOIS
 DEPARTMENT OF TRANSPORTATION

U.S. ROUTE 30 AT IL ROUTE 31
 PROPOSED LIGHTING PLANS (SHEET 1 OF 6)

SCALE: AS NOTED | SHEET NO. 4 OF 27 SHEETS | STA. ----- TO STA. -----

F.A.P. RTE.	SECTION	COUNTY	TOTAL SHEETS	SHEET NO.
349	(10 & 11 VB) R-3	*	507	198
* KANE AND KENDALL			CONTRACT NO. 60133	
ILLINOIS FED. AID PROJECT				