



F.A.P. RTE.	SECTION	COUNTY	TOTAL SHEETS	SHEET NO.
607	129 BR	KENDALL	61	13
STA.	TO STA.			
FED. ROAD DIST. NO.	ILLINOIS	FED. AID PROJECT		

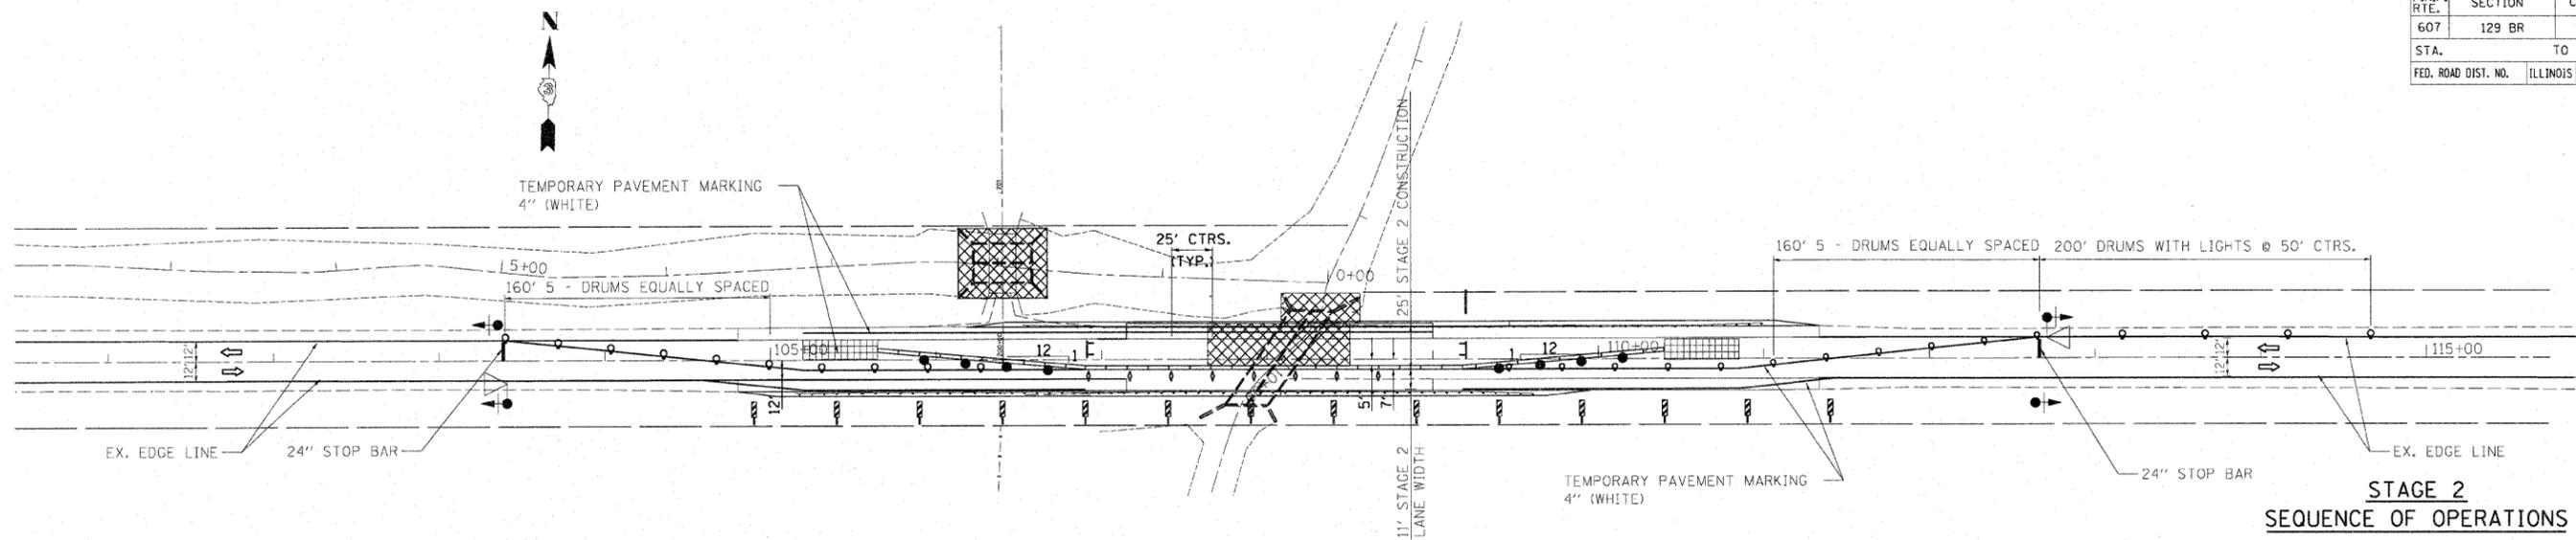


**TRAFFIC CONTROL SCHEMATIC**

**STAGE 2  
SEQUENCE OF OPERATIONS**

1. INSTALL TEMPORARY CONCRETE BARRIERS AND DRUMS USING TRAFFIC CONTROL AND PROTECTION STANDARDS 701006 AND 701201. ALL OTHER ITEMS AS PER THESE DETAILS AND AS PER LANE CLOSURE 2L, 2W, BRIDGE REPAIR WITH BARRIER STANDARD 701321. BEGIN OPERATING UNDER STAGE 2 TRAFFIC CONDITIONS.
2. THE CONTRACTOR SHALL REMOVE EXISTING STRUCTURE (SN 047-0046) AND REPLACE WITH 11' X 8' PRECAST CONCRETE DOUBLE BOX CULVERT (SN 047-2020). THE BRIDGE CAN ONLY BE CLOSED AFTER THE PLANTING SEASON ENDS - AFTER JUNE 1.
3. REMOVE ALL REMAINING EXISTING ITEMS SUCH AS GUARDRAIL, TRAFFIC BARRIER TERMINALS AND REMAINING PORTIONS OF EXISTING STRUCTURE. REMOVE 18" CULVERT AT STA. 109+00 RT.
4. CONSTRUCT NEW PORTIONS OF PROPOSED STRUCTURE, BACKFILL AND COMPACT. INSTALL NORTH LANE ROADWAY HMA BASE COURSE, AND INSTALL TRAFFIC BARRIER TERMINALS AND GUARDRAIL. OVERLAY PAVEMENT AND SHOULDERS.
5. REMOVE ALL TEMPORARY TRAFFIC CONTROL DEVICES. PLACE FINAL STRIPING. ALL OF WORK WILL BE DONE IN ACCORDANCE WITH STANDARDS 701306, 701311 AND 702001.

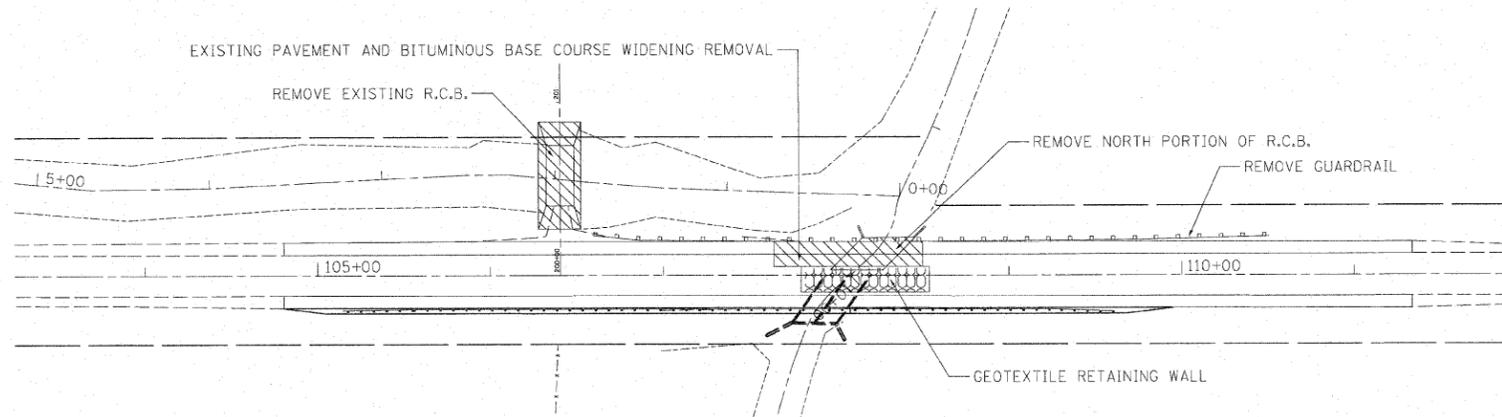

**REMOVAL SCHEMATIC**

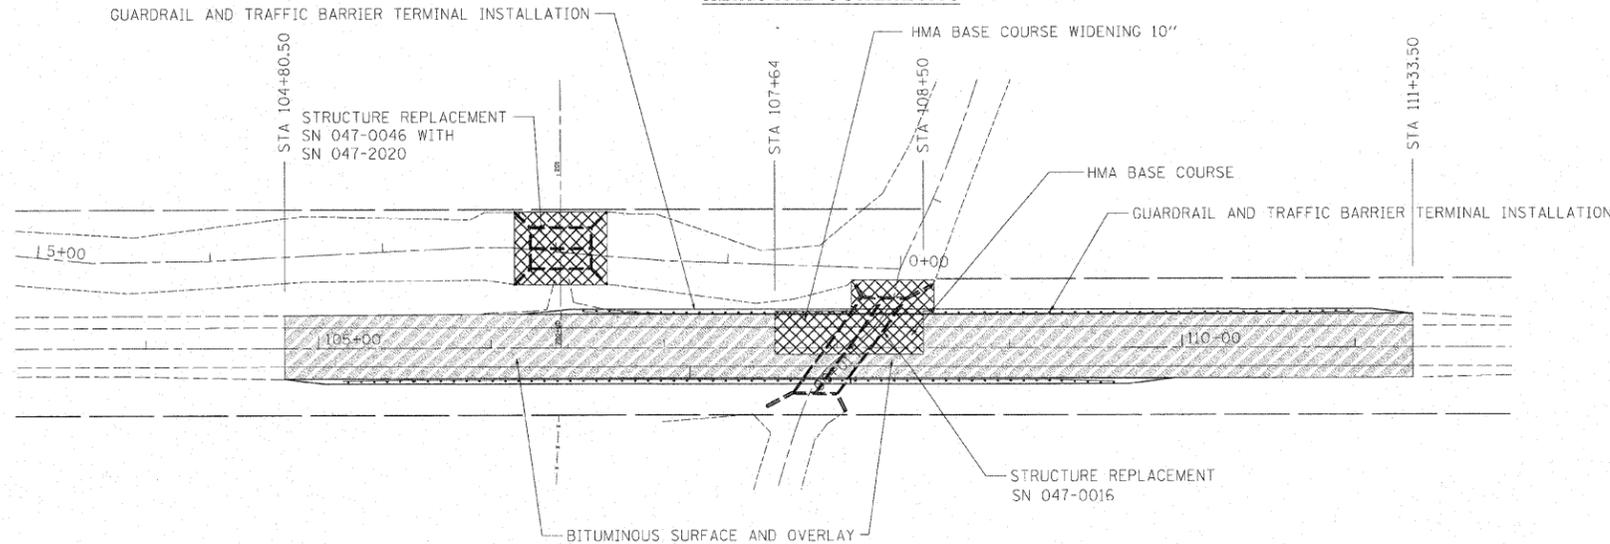

**CONSTRUCTION SCHEMATIC**

**LEGEND**

- GEOTEXTILE RETAINING WALL
- WORK AREA
- REMOVAL AREA (SEE NOTES)
- HMA OVERLAY
- TYPE III BARRICADE
- MICROWAVE DETECTOR
- TRAFFIC SIGNALS WITH BACKPLATE
- DRUM WITH STEADY BURNING LIGHT
- STOP LINE 24"
- TEMPORARY IMPACT ATTENUATOR (NON-REDIRECTIVE) RESERVE AREA
- DOUBLE VERTICAL PANEL
- TYPE C BIDIRECTIONAL REFLECTOR
- STEADY BURNING LIGHTS AND DOUBLE VERTICAL PANEL

REVISIONS	
NAME	DATE

ILLINOIS DEPARTMENT OF TRANSPORTATION

**STAGING PLANS  
STAGE 2 CONSTRUCTION**

SCALE: VERT. NOT TO SCALE  
 HORIZ. NOT TO SCALE  
 DATE 10/17/2007  
 DRAWN BY C. SUNTKEN  
 CHECKED BY M. ZELINSKAS

PLOT DATE = 10/17/2007  
 FILE NAME = M:\OFFICE\66667\1\From Dub 12-24-08\12001.dgn  
 PLOT SCALE = \$SCALE\$  
 USER NAME = JUSER