


PLAN	SURVEYED	DATE
	PLOTTED	BY
	CHECKED	
	AT	
	FILE NAME	
	NO.	

PROFILE	SURVEYED	DATE
	PLOTTED	BY
	CHECKED	
	AT	
	STRUCTURE	
	NOT AT THIS OFFICE	
	NO.	



DRAINAGE STAGING NOTES

- CONTRACTOR SHALL MAINTAIN DRAINAGE FOR ALL OVERLAND FLOWS, PIPES AND TILES THAT ENTER THE RIGHT-OF-WAY. THIS WORK IS INCIDENTAL TO THE VARIOUS DRAINAGE ITEMS AND GRADING WORK INCLUDED IN THE CONTRACT.
- CONTRACTOR SHALL PERFORM EXPLORATION TRENCH 52" DEPTH WORK IN PRE-STAGE TO LOCATE EXISTING DRAIN TILES BOTH ENTERING AND EXITING THE PROPOSED RIGHT-OF-WAY, TO DETERMINE LOCATION AND INVERT ELEVATION. CONTRACTOR SHOULD REFER TO DRAINAGE AND UTILITY PLANS FOR LOCATIONS WHERE DRAIN TILE MAY BE FOUND, WHICH IS BASED ON THE BEST AVAILABLE INFORMATION.
- CONTRACTOR SHALL VERIFY THAT EACH TILE ENTERING THE RIGHT-OF-WAY WILL HAVE A POSITIVE OUTFALL INTO A PROPOSED DITCH, PIPE OR ACROSS RIGHT-OF-WAY AND INTO AN OFFSITE TILE THROUGH STORM SEWER PROTECTED AND STORM SEWER (SPECIAL). STAGING OF THIS WORK SHALL BE COORDINATED WITH THE MAINTENANCE OF TRAFFIC PLAN STAGES.
- PIPE UNDERDRAINS SHALL BE INSTALLED WITH PERMANENT PAVEMENT AND CONNECTED TO STRUCTURE, PIPE, CULVERT AND PIPE UNDERDRAIN (SPECIAL). STAGING OF THIS WORK SHALL BE COORDINATED WITH THE MAINTENANCE OF TRAFFIC PLANS AND IS INCIDENTAL TO THE COST OF PIPE UNDERDRAINS AN PIPE UNDERDRAINS (SPECIAL).

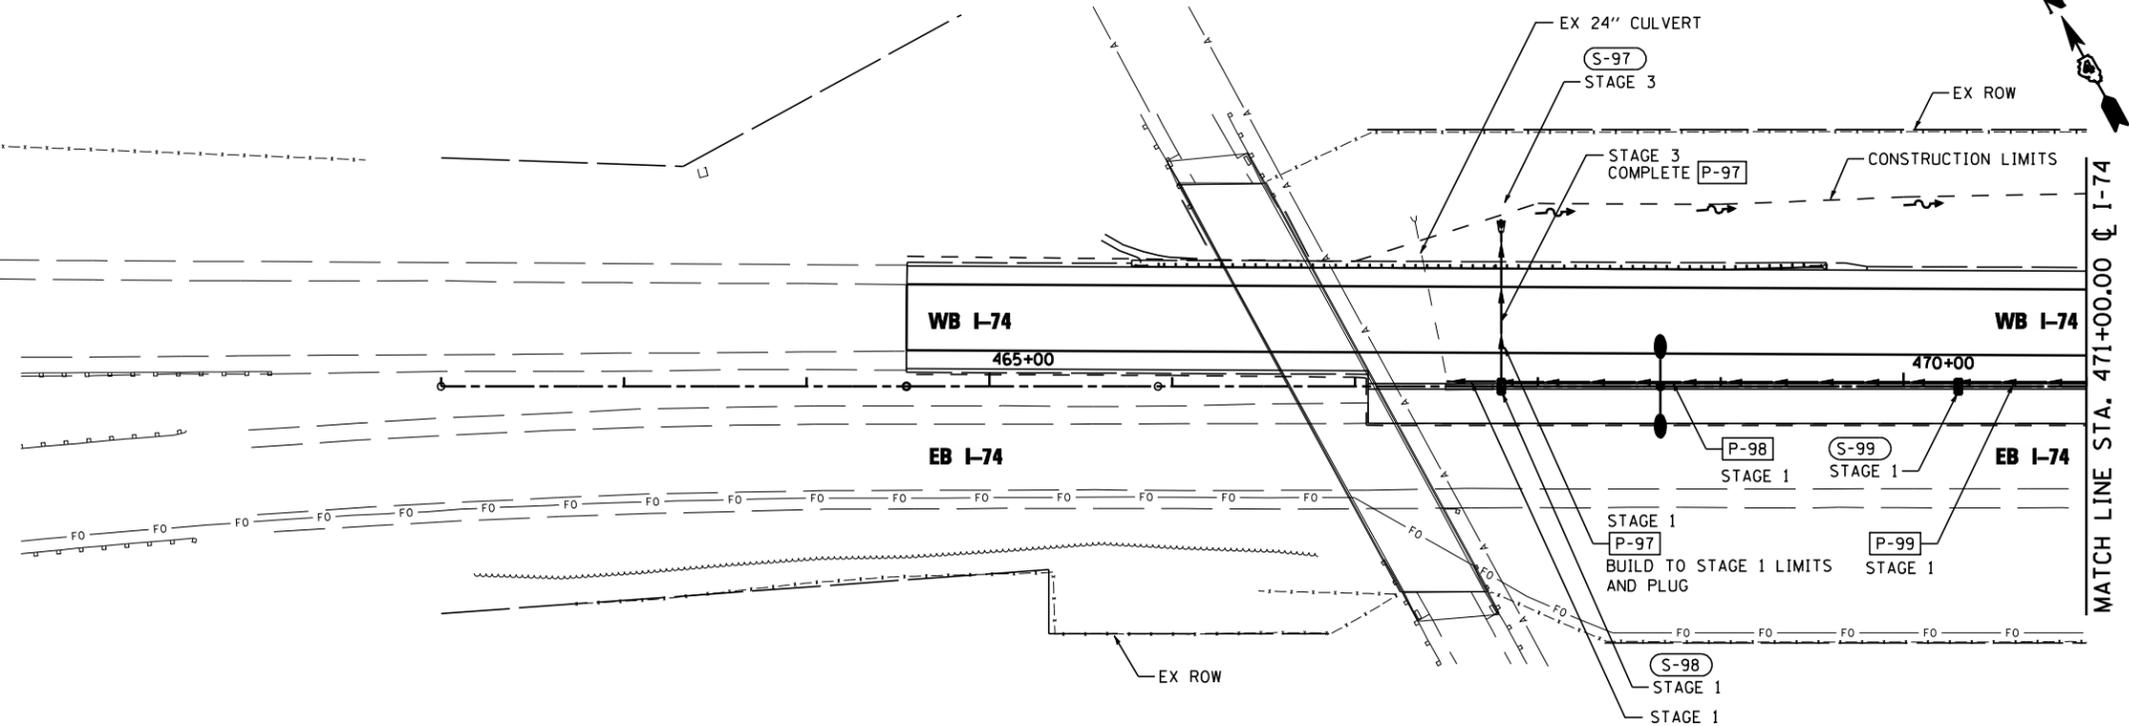

LEGEND:

- A — EXISTING AERIAL LINE
- CTV — EXISTING UNDERGROUND CABLE TV
- E — EXISTING UNDERGROUND ELECTRIC
- FO — EXISTING UNDERGROUND FIBER OPTIC
- IG — EXISTING UNDERGROUND GAS LINE
- T — EXISTING UNDERGROUND SANITARY SEWER
- W — EXISTING UNDERGROUND TELEPHONE
- W — EXISTING UNDERGROUND WATER
- — PROPOSED STORM SEWER
- — PROPOSED PIPE UNDERDRAIN
- (S-101B) — PROPOSED STORM SEWER STRUCTURE CALLOUTS
- (P-101) — PROPOSED STORM SEWER PIPE CALLOUTS
- — SAG
- — SUMMIT
- — DITCH
- — SWALE
- — MANHOLE

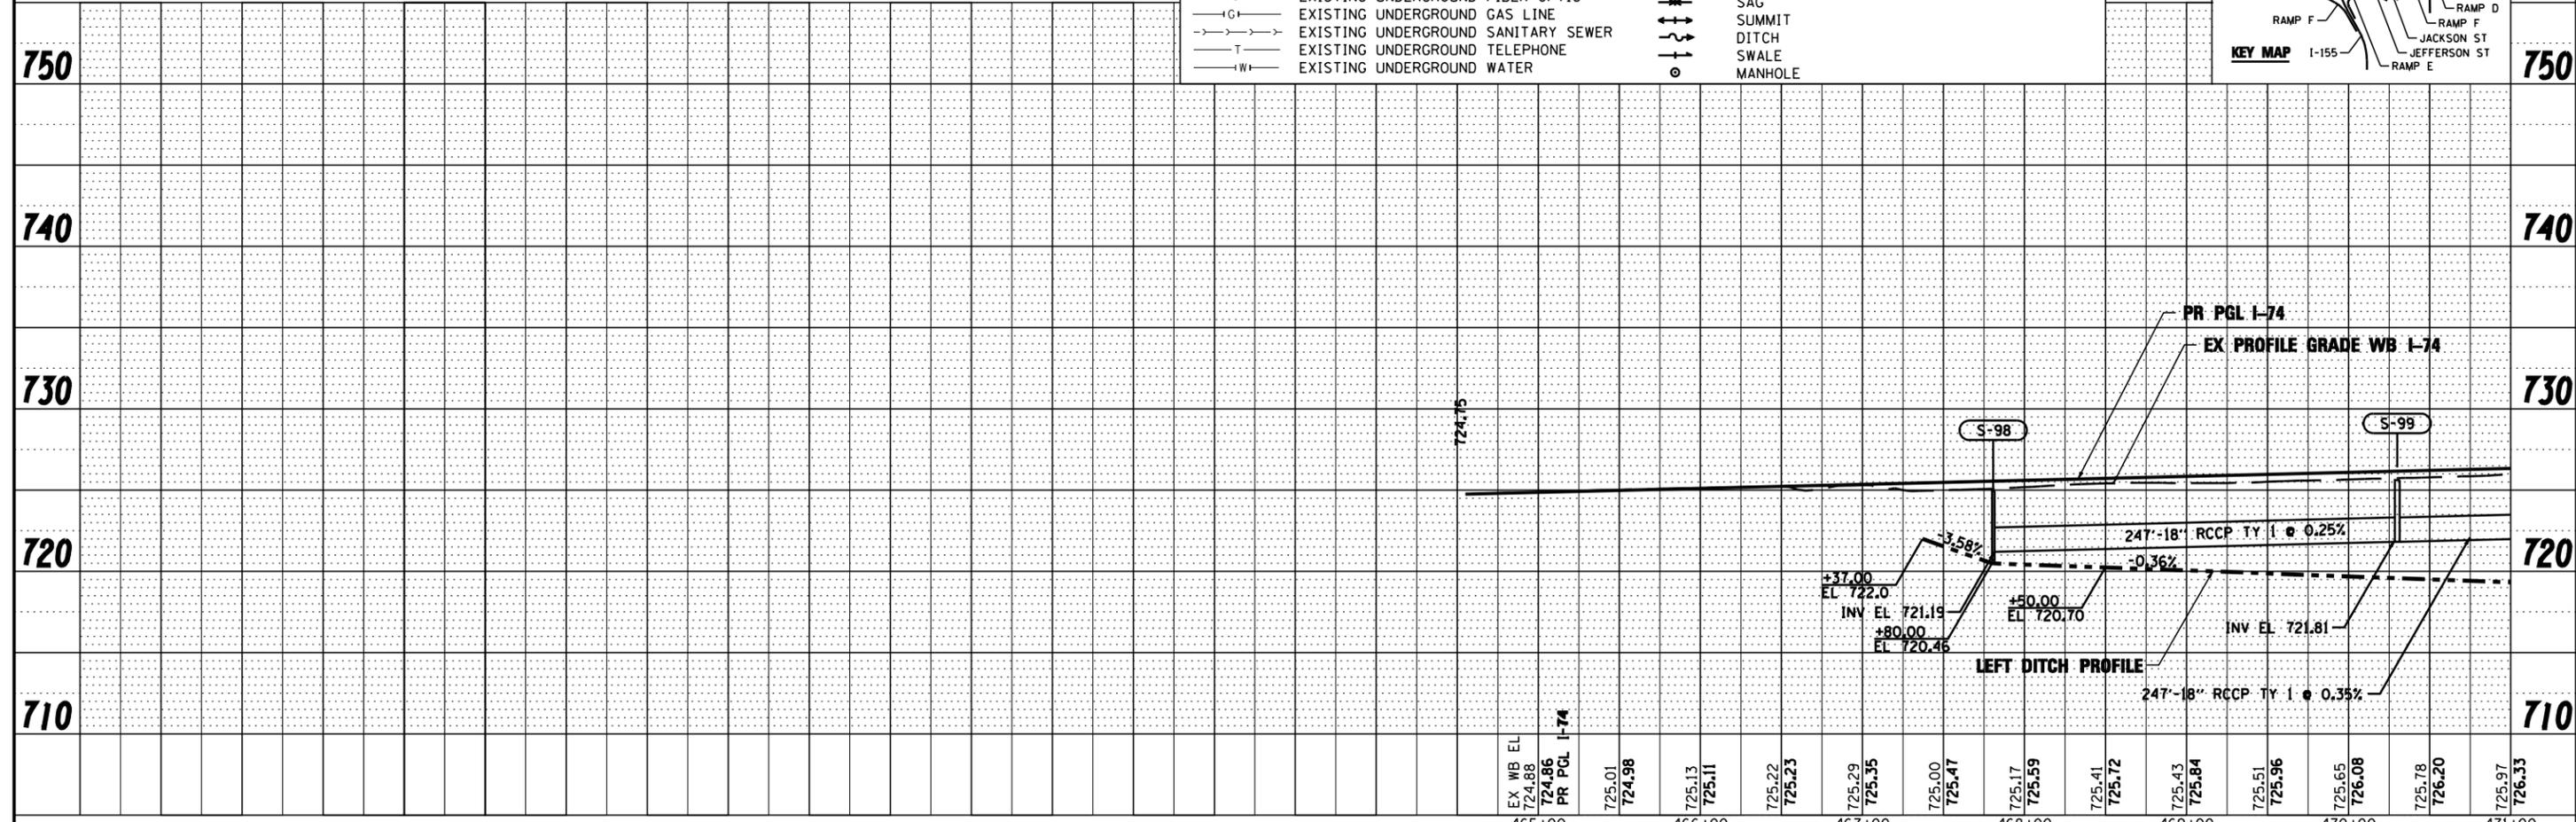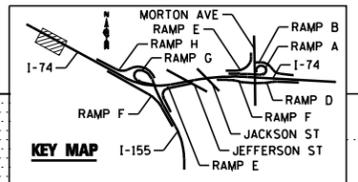

FILE NAME =	DESIGNED - WLS	REVISED -		STATE OF ILLINOIS DEPARTMENT OF TRANSPORTATION		I-74 DRAINAGE STAGING PLAN STA 464+55 TO STA 471+00		F.A.I. SECTION	COUNTY	TOTAL SHEETS	SHEET NO.
...D468620-sh1-1-74-MDTdrain00.dgn	DRAWN - I S	REVISED -						90-114R(14HB-4,14,14HVB)BR	TAZEWELL	2433	1309
USER NAME = toddb1enk	CHECKED - JNR	REVISED -						CONTRACT NO. 68620			
PLOT DATE = 7/18/2012	DATE - JULY 20, 2012	REVISED -						ILLINOIS FED. AID PROJECT			