


TYPICAL SPLICE DETAIL

N.T.S.

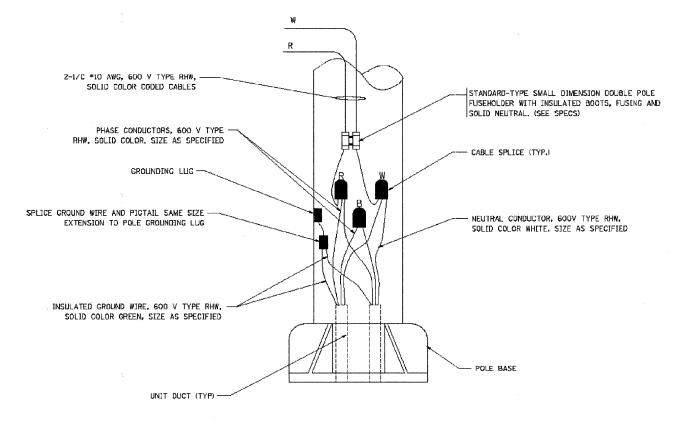

AS APPROVED BY THE ENGINEER

12" (305)

WARNING TAPE AS SPECIFIED

UNIT DUCT OR OTHER RACEWAY
AND WIRING AS PER PLANS, COMPLETE
WITH INTERNAL INSULATED
EQUIPMENT GROUND WIRE.

- 12" (305) MAXIMUM WIDTH EXCEPT

TYPICAL WIRING IN TRENCH DETAIL N.T.S.

POLE WIRING DETAIL

N.T.S.

SCHAUMBIRG, ILLINOIS 60173

FILE NAME =	USER NAME = gaglianobt	DESIGNED	REVISED - 08/08/03			F.A.P. RTF.	SECTION	COUNTY	TOTAL SHEET
W:\diststd \ 22x34\be702.dgn		DRAWN	REVISED -	STATE OF ILLINOIS	DISTRICT ONE - MISC. ELECTRICAL DETAILS SHEET A		00243-00-CH	СООК	142 101
	PLOT SCALE = 20.000 '/ IN.	CHECKED	REVISED -	DEPARTMENT OF TRANSPORTATION		BE-	-702	CONTRACT	NO. 63566
	PLOT DATE = 11/4/2011	DATE	REVISED -		SCALE: N.T.S. SHEET NO. 11 OF 12 SHEETS STA. TO STA.	FED. ROAD DIST. NO. 7 ILLINOIS FED. AID PROJECT			