
STA. 1376+00.00 TO STA. 1388+00.00 **→**�→Z FED. ROAD DIST. NO. 1 ILLINOIS FED. AID PROJECT 62583

NOTES:

1. SEE DRAWINGS ME-01 AND ME-02 FOR ELECTRICAL SYMBOLS AND ABBREVIATIONS.

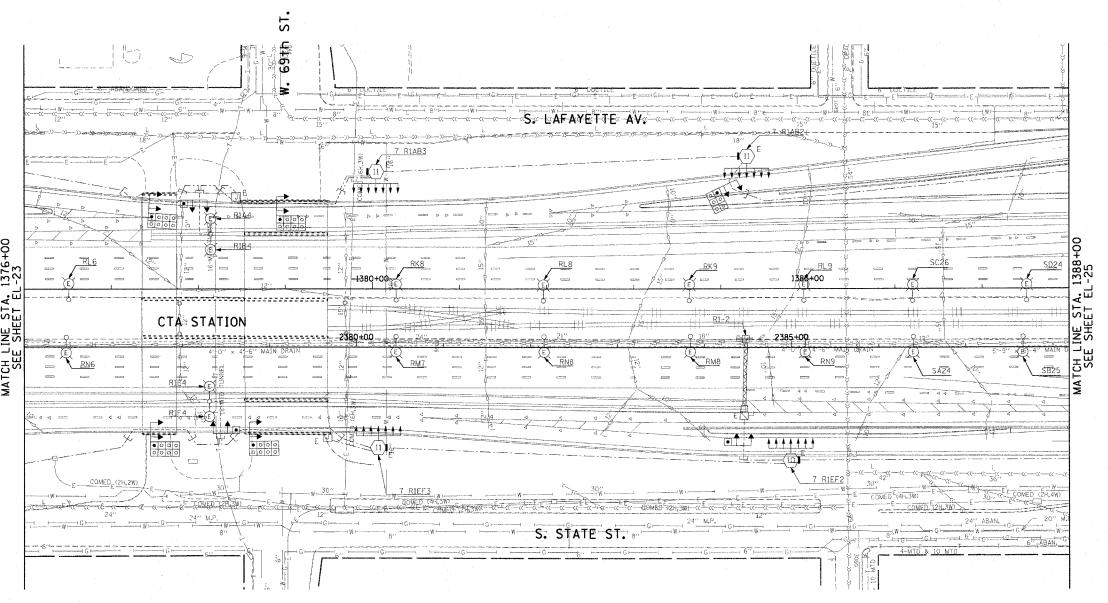

THIS SHEET IS FOR INFORMATIONAL PURPOSES ONLY. HIGH MAST LIGHT TOWERS, CONTROLLERS, AND WIRING ARE INSTALLED IN IDOT CONTRACT NO. 62733.

0 50' 100' 1" = 50'

EL-24

REVISIONS NAME DATE		ILLINOIS DEPARTMENT OF TRANSPORTATION F.A.I. 90/94 (DAN RYAN EXPRESSWAY)
		31st STREET TO I-57
		ROADWAY LIGHTING PLANS EXISTING CONDITIONS AND DEMOLITION

DATE: October 29, 2004

DRAWN BY: CJM CHECKED BY: WDS

CTE ENGINEERS CONSOER TOWNSEND ENVIRODANCE ENGINEERS, INC. 303 EAST WACKER DRIVE, SUITE 600 CHICAGO ILLINOIS 60601-52/2, PHONE: (3/2) 938-0300