



Hanson Professional Services Inc.  
 Suite 200, 819 Commerce Drive  
 Oak Brook, Illinois 60521  
 © Copyright Hanson Professional Services Inc. 2008

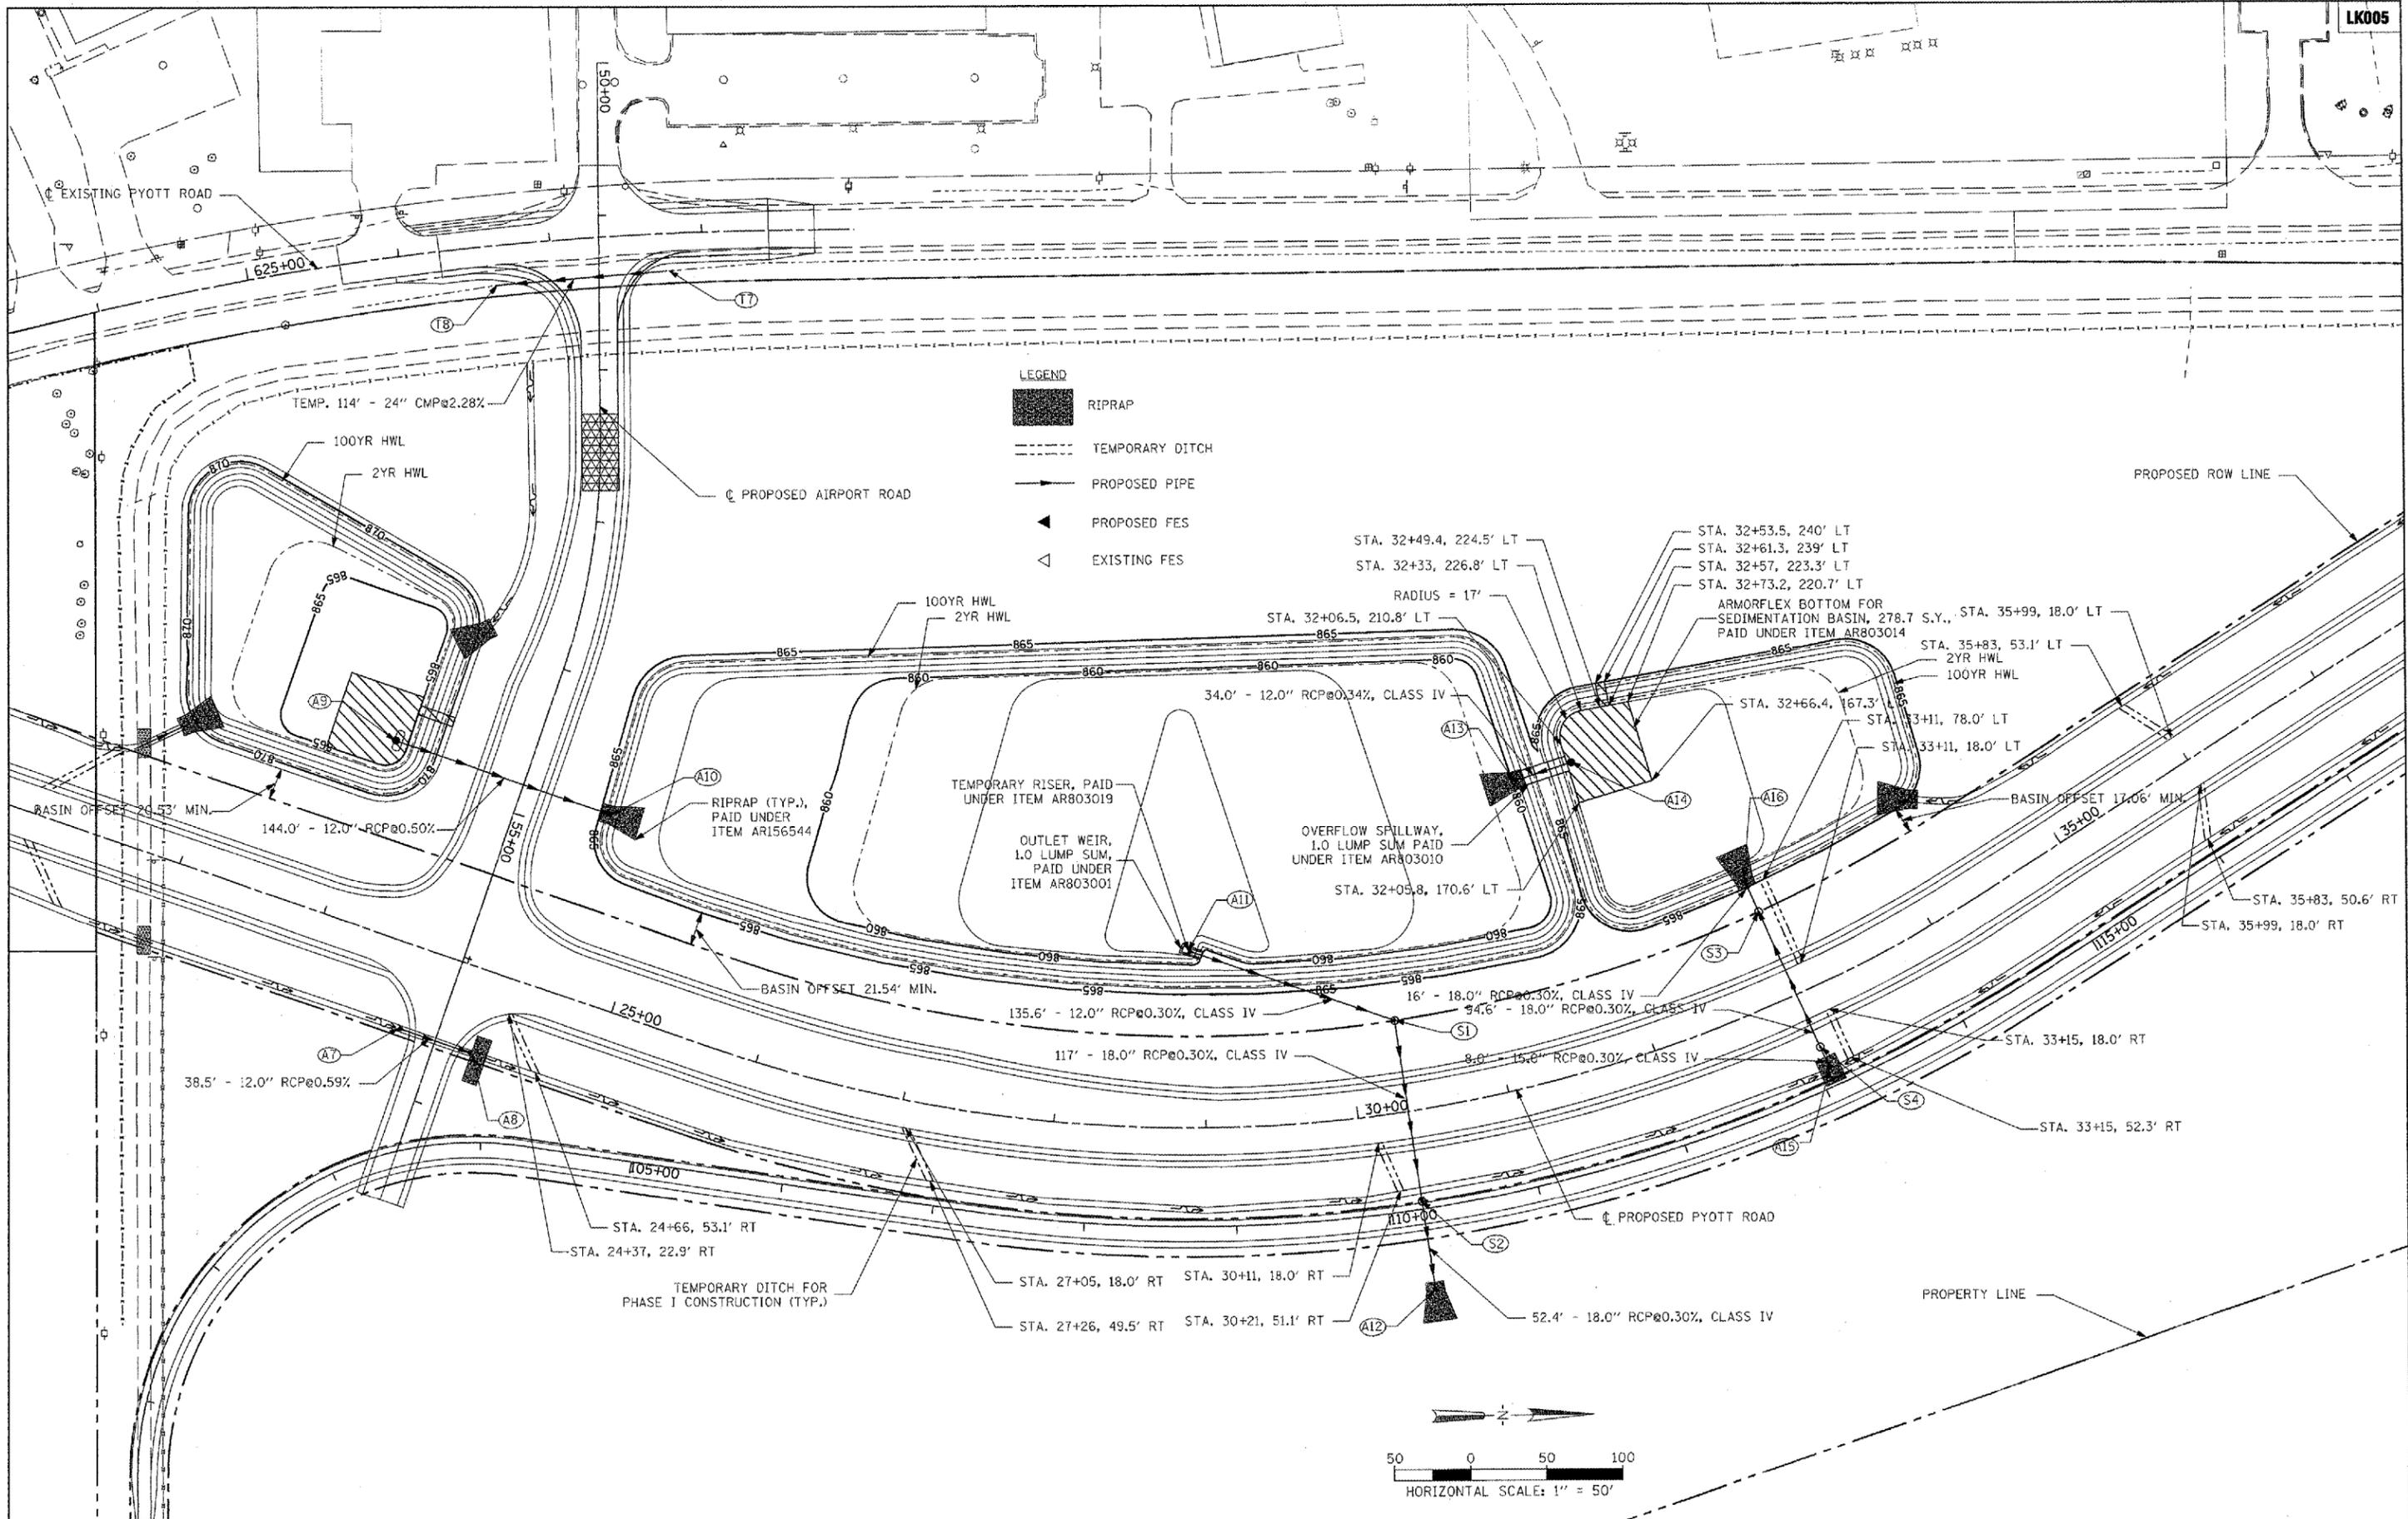

**LEGEND**

- RIPRAP
- TEMPORARY DITCH
- PROPOSED PIPE
- PROPOSED FES
- EXISTING FES

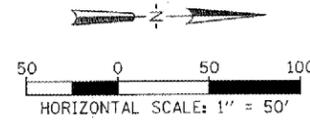

FILE NAME = I:\05\Jobs\00841\0568021\Civil Part A\Sheets\DRN3.sht	USER NAME = McLeu01058	DESIGNED - SJM	REVISED -	<b>VILLAGE OF LAKE IN THE HILLS, ILLINOIS</b>	<b>DRAINAGE PLAN PYOTT ROAD</b>		COUNTY	TOTAL SHEETS	SHEET NO.
		DRAWN - SJM	REVISED -		MCHENRY	120	28		
PLOT SCALE = 1/8" = 1' / IN.	CHECKED - BLB	REVISED -	SCALE: 1" = 50'		FEDERAL AIP NO. 3-17-0112-88	ILLINOIS	IDA NO. 3CK-3671		
PLOT DATE = 02/29/08, 08:41 AM	DATE - 02/29/08	REVISED -							