

MODEL: Default
FILE NAME: W:\894-088 Randall at Higgins Phase II Engineering\CADD Sheets\011 Drainage and Utilities Plans\18c00514c0bVR Plan_020.dgn



BLA, Inc.


USER NAME = cesario	DESIGNED - TN	REVISED -
	DRAWN - TN	REVISED -
PLOT SCALE = 48.0000' / in.	CHECKED - GJE	REVISED -
PLOT DATE = 6/19/2025	DATE - 02/15/2025	REVISED -

 
STATE OF ILLINOIS
DEPARTMENT OF TRANSPORTATION

RANDALL ROAD AT IL ROUTE 72 (HIGGINS ROAD)
DRAINAGE AND UTILITY PLAN AND PROFILE

SCALE: 1" = 20' SHEET 1 OF 19 SHEETS STA. TO STA.


F.A.P. RTE.	SECTION	COUNTY	TOTAL SHEETS	SHEET NO.
0336	19-00514-00-WR	KANE	304	101
CONTRACT NO. 61L28				
ILLINOIS FED. AID PROJECT				

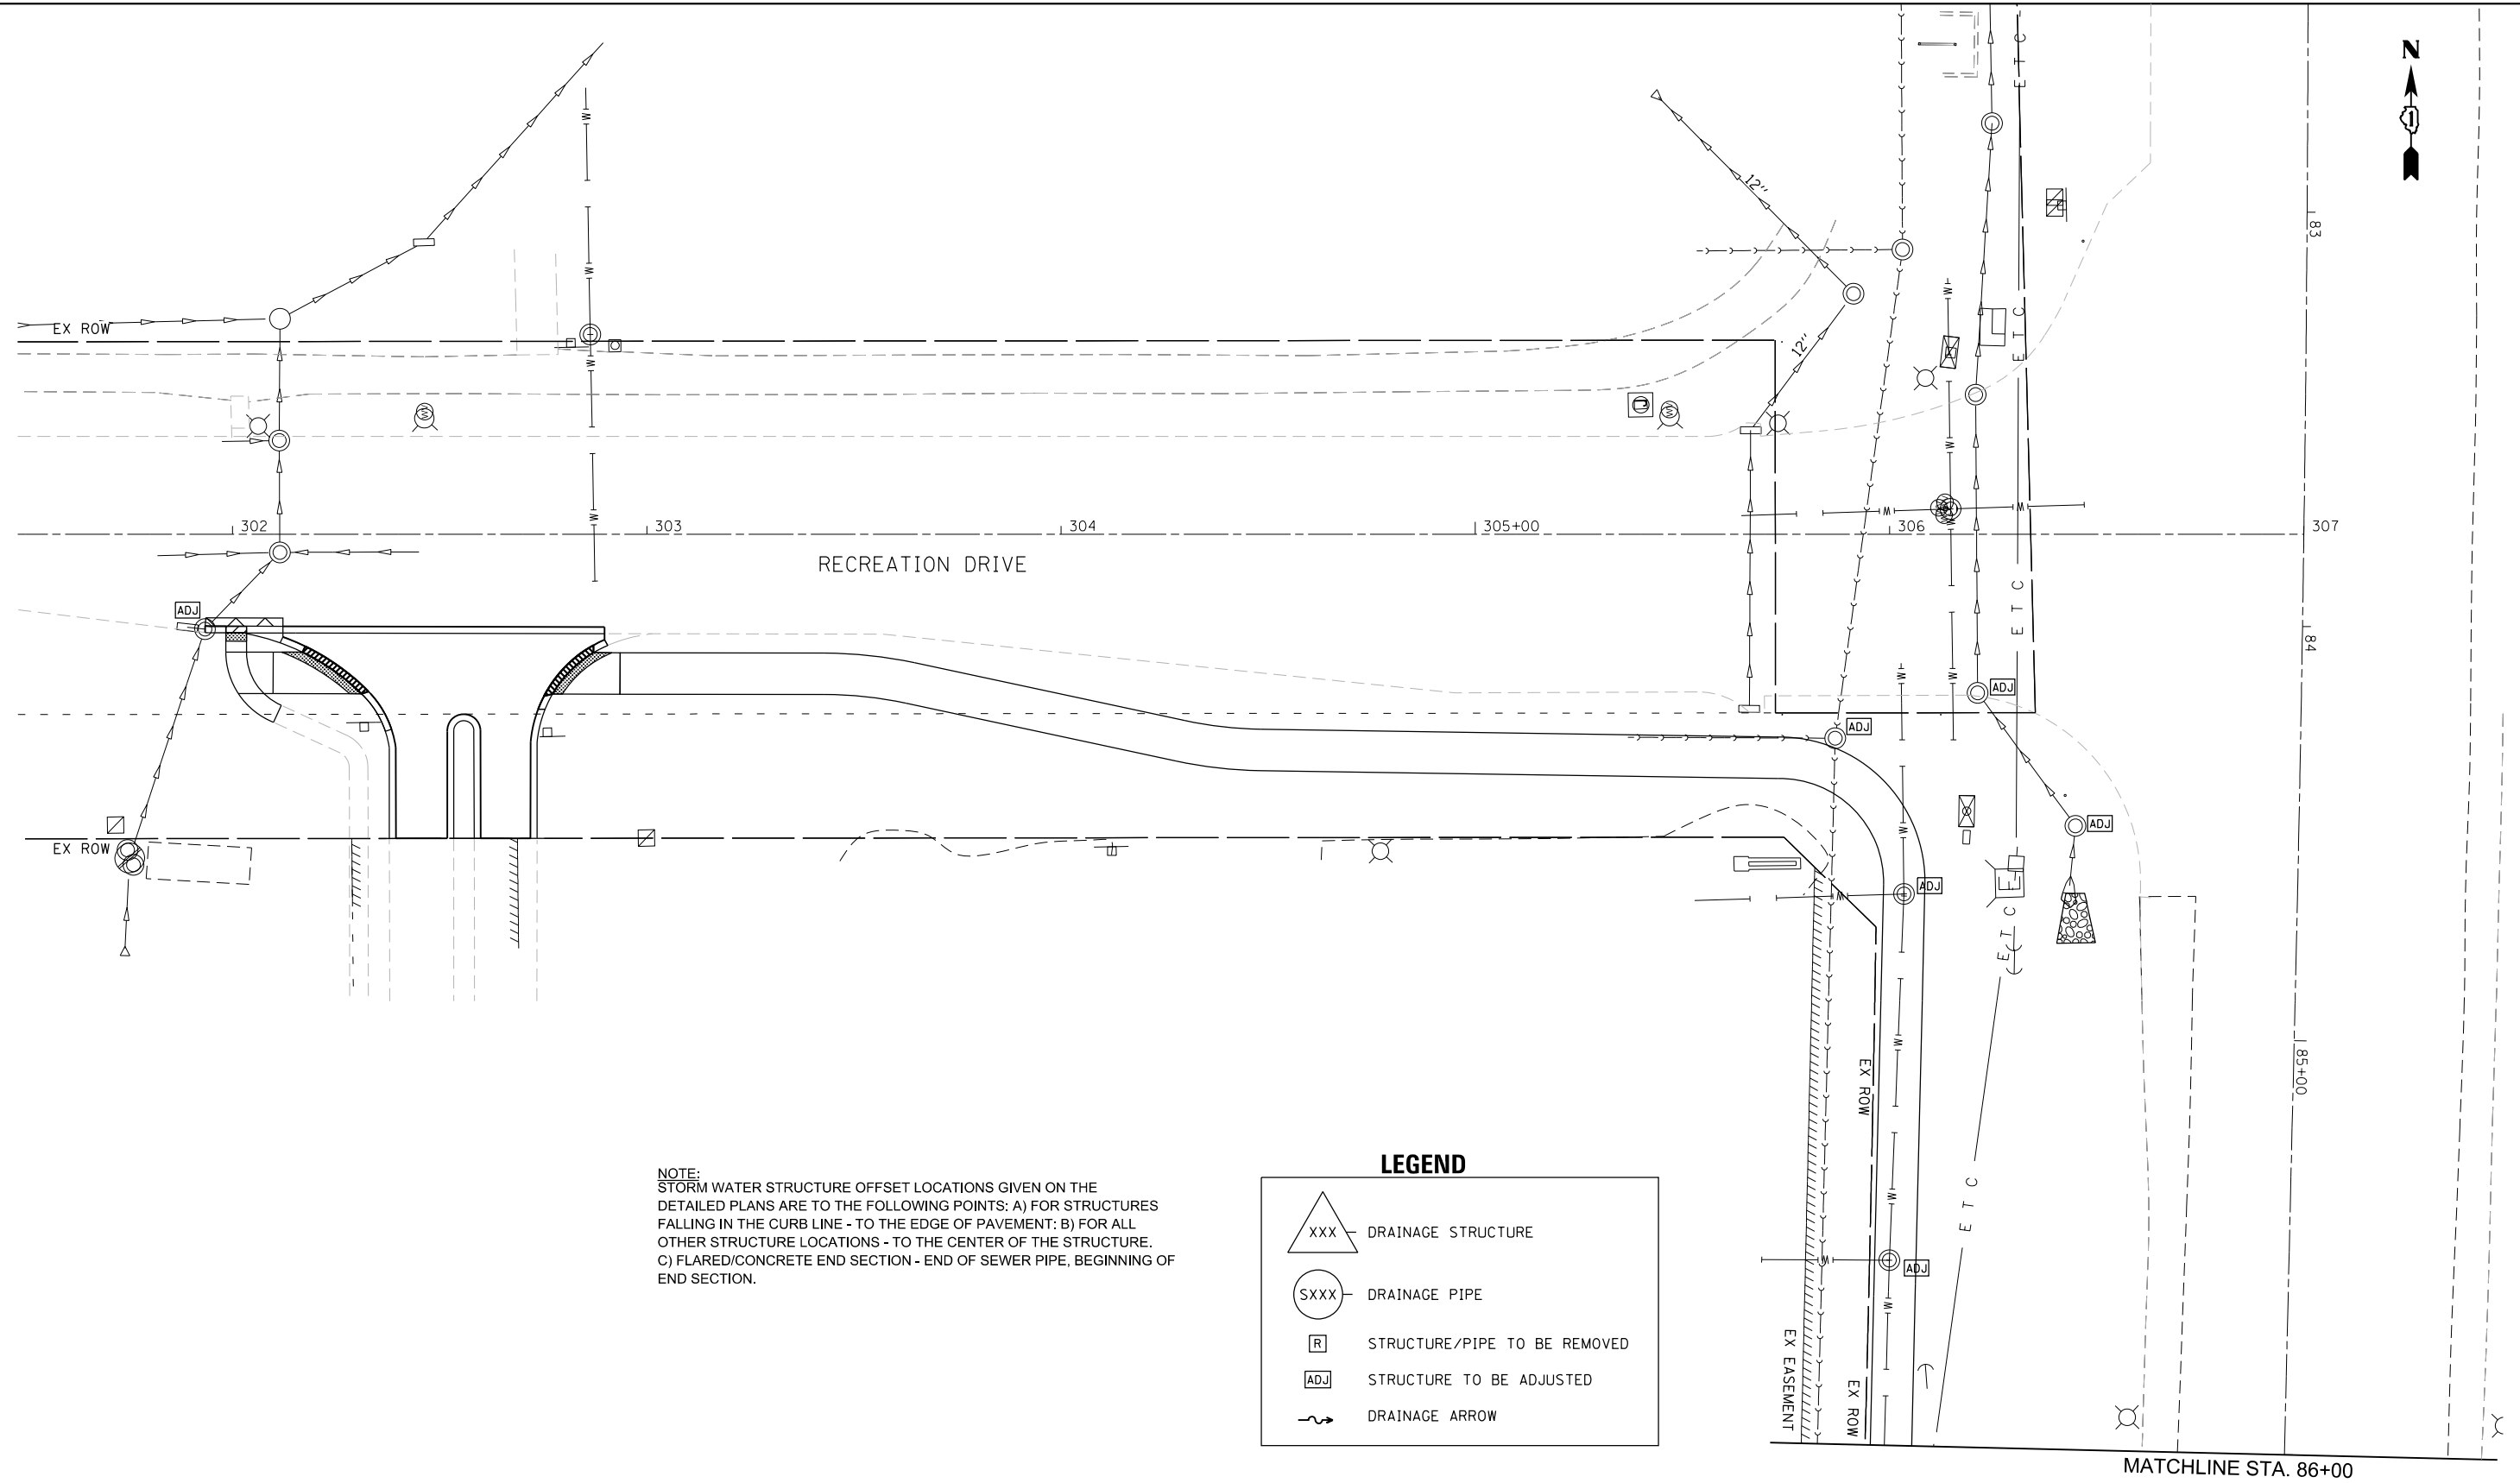




F.A.P. RTE.	SECTION	COUNTY	TOTAL SHEETS	SHEET NO.
0336	19-00514-00-WR	KANE	304	102
		CONTRACT NO. 61L28		
ILLINOIS FED. AID PROJECT				

PLAN	SURVEYED	BY	DATE
	PLOTTED		
NOTE BOOK NO.	CHECKED		
	NO.		

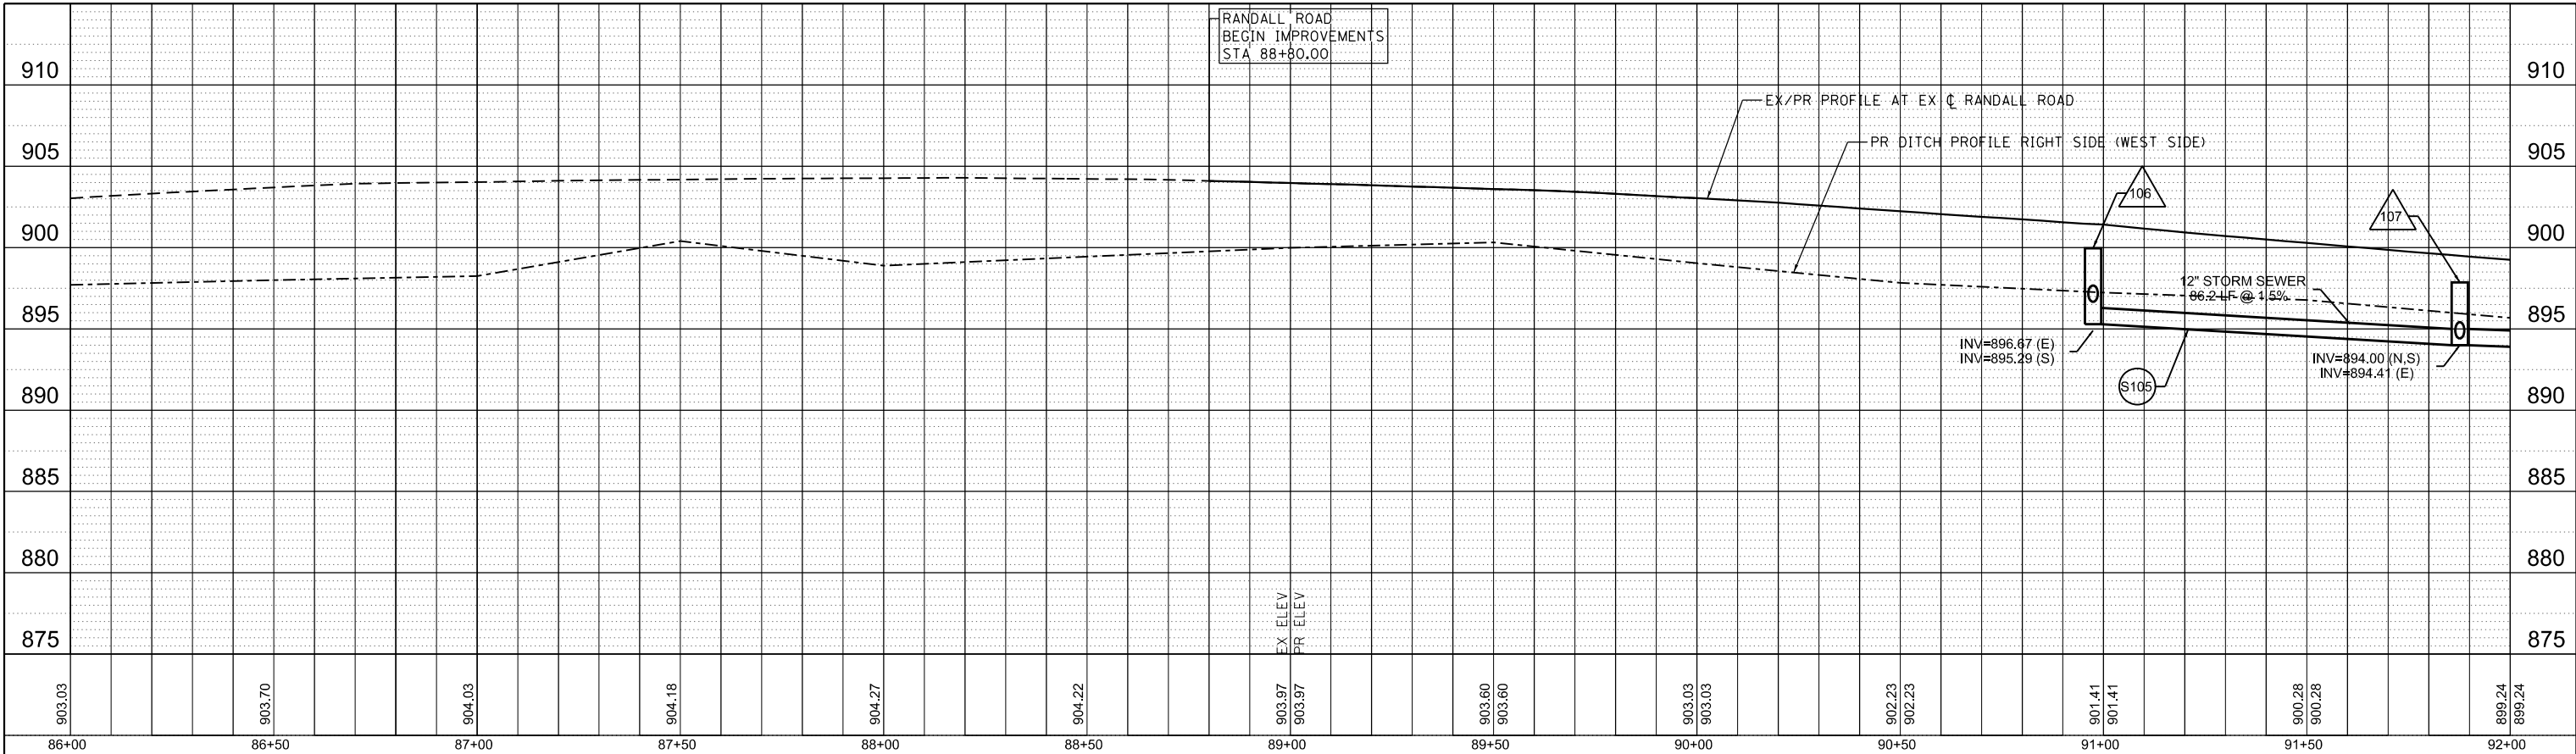

PROFILE	SURVEYED	BY	DATE
	PLOTTED		
NOTE BOOK NO.	GRADES CHECKED		
	STRUCTURE		


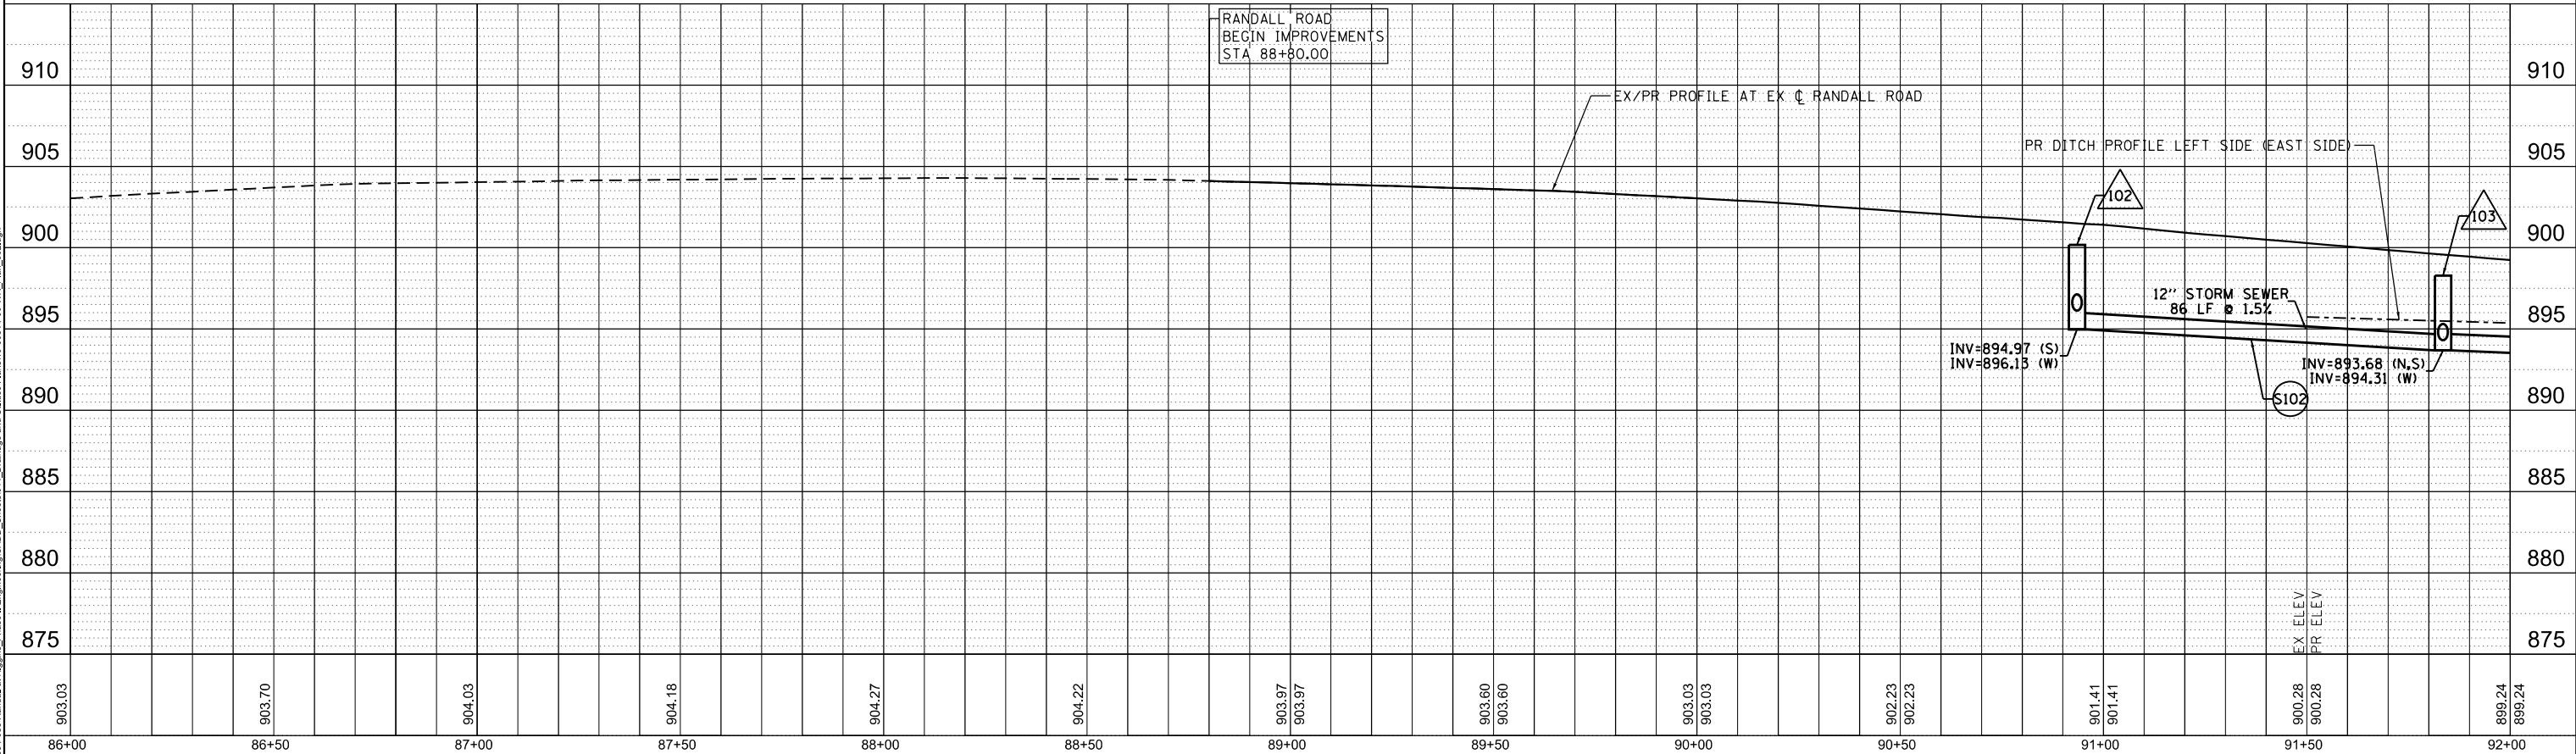


MODEL: Default
FILE NAME: W:\894-088 Randall at Higgins Phase II Engineering\CADD Sheets\011 Drainage and Utilities Plans\180514-00-WR Plan_003.dgn

LEGEND

- XXX DRAINAGE STRUCTURE
- SXXX DRAINAGE PIPE
- [R] STRUCTURE/PIPE TO BE REMOVED
- [ADJ] STRUCTURE TO BE ADJUSTED
- ~ DRAINAGE ARROW

 NOTE:
STORM WATER STRUCTURE OFFSET LOCATIONS GIVEN ON THE DETAILED PLANS ARE TO THE FOLLOWING POINTS: A) FOR STRUCTURES FALLING IN THE CURB LINE - TO THE EDGE OF PAVEMENT; B) FOR ALL OTHER STRUCTURE LOCATIONS - TO THE CENTER OF THE STRUCTURE. C) FLARED/CONCRETE END SECTION - END OF SEWER PIPE, BEGINNING OF END SECTION.

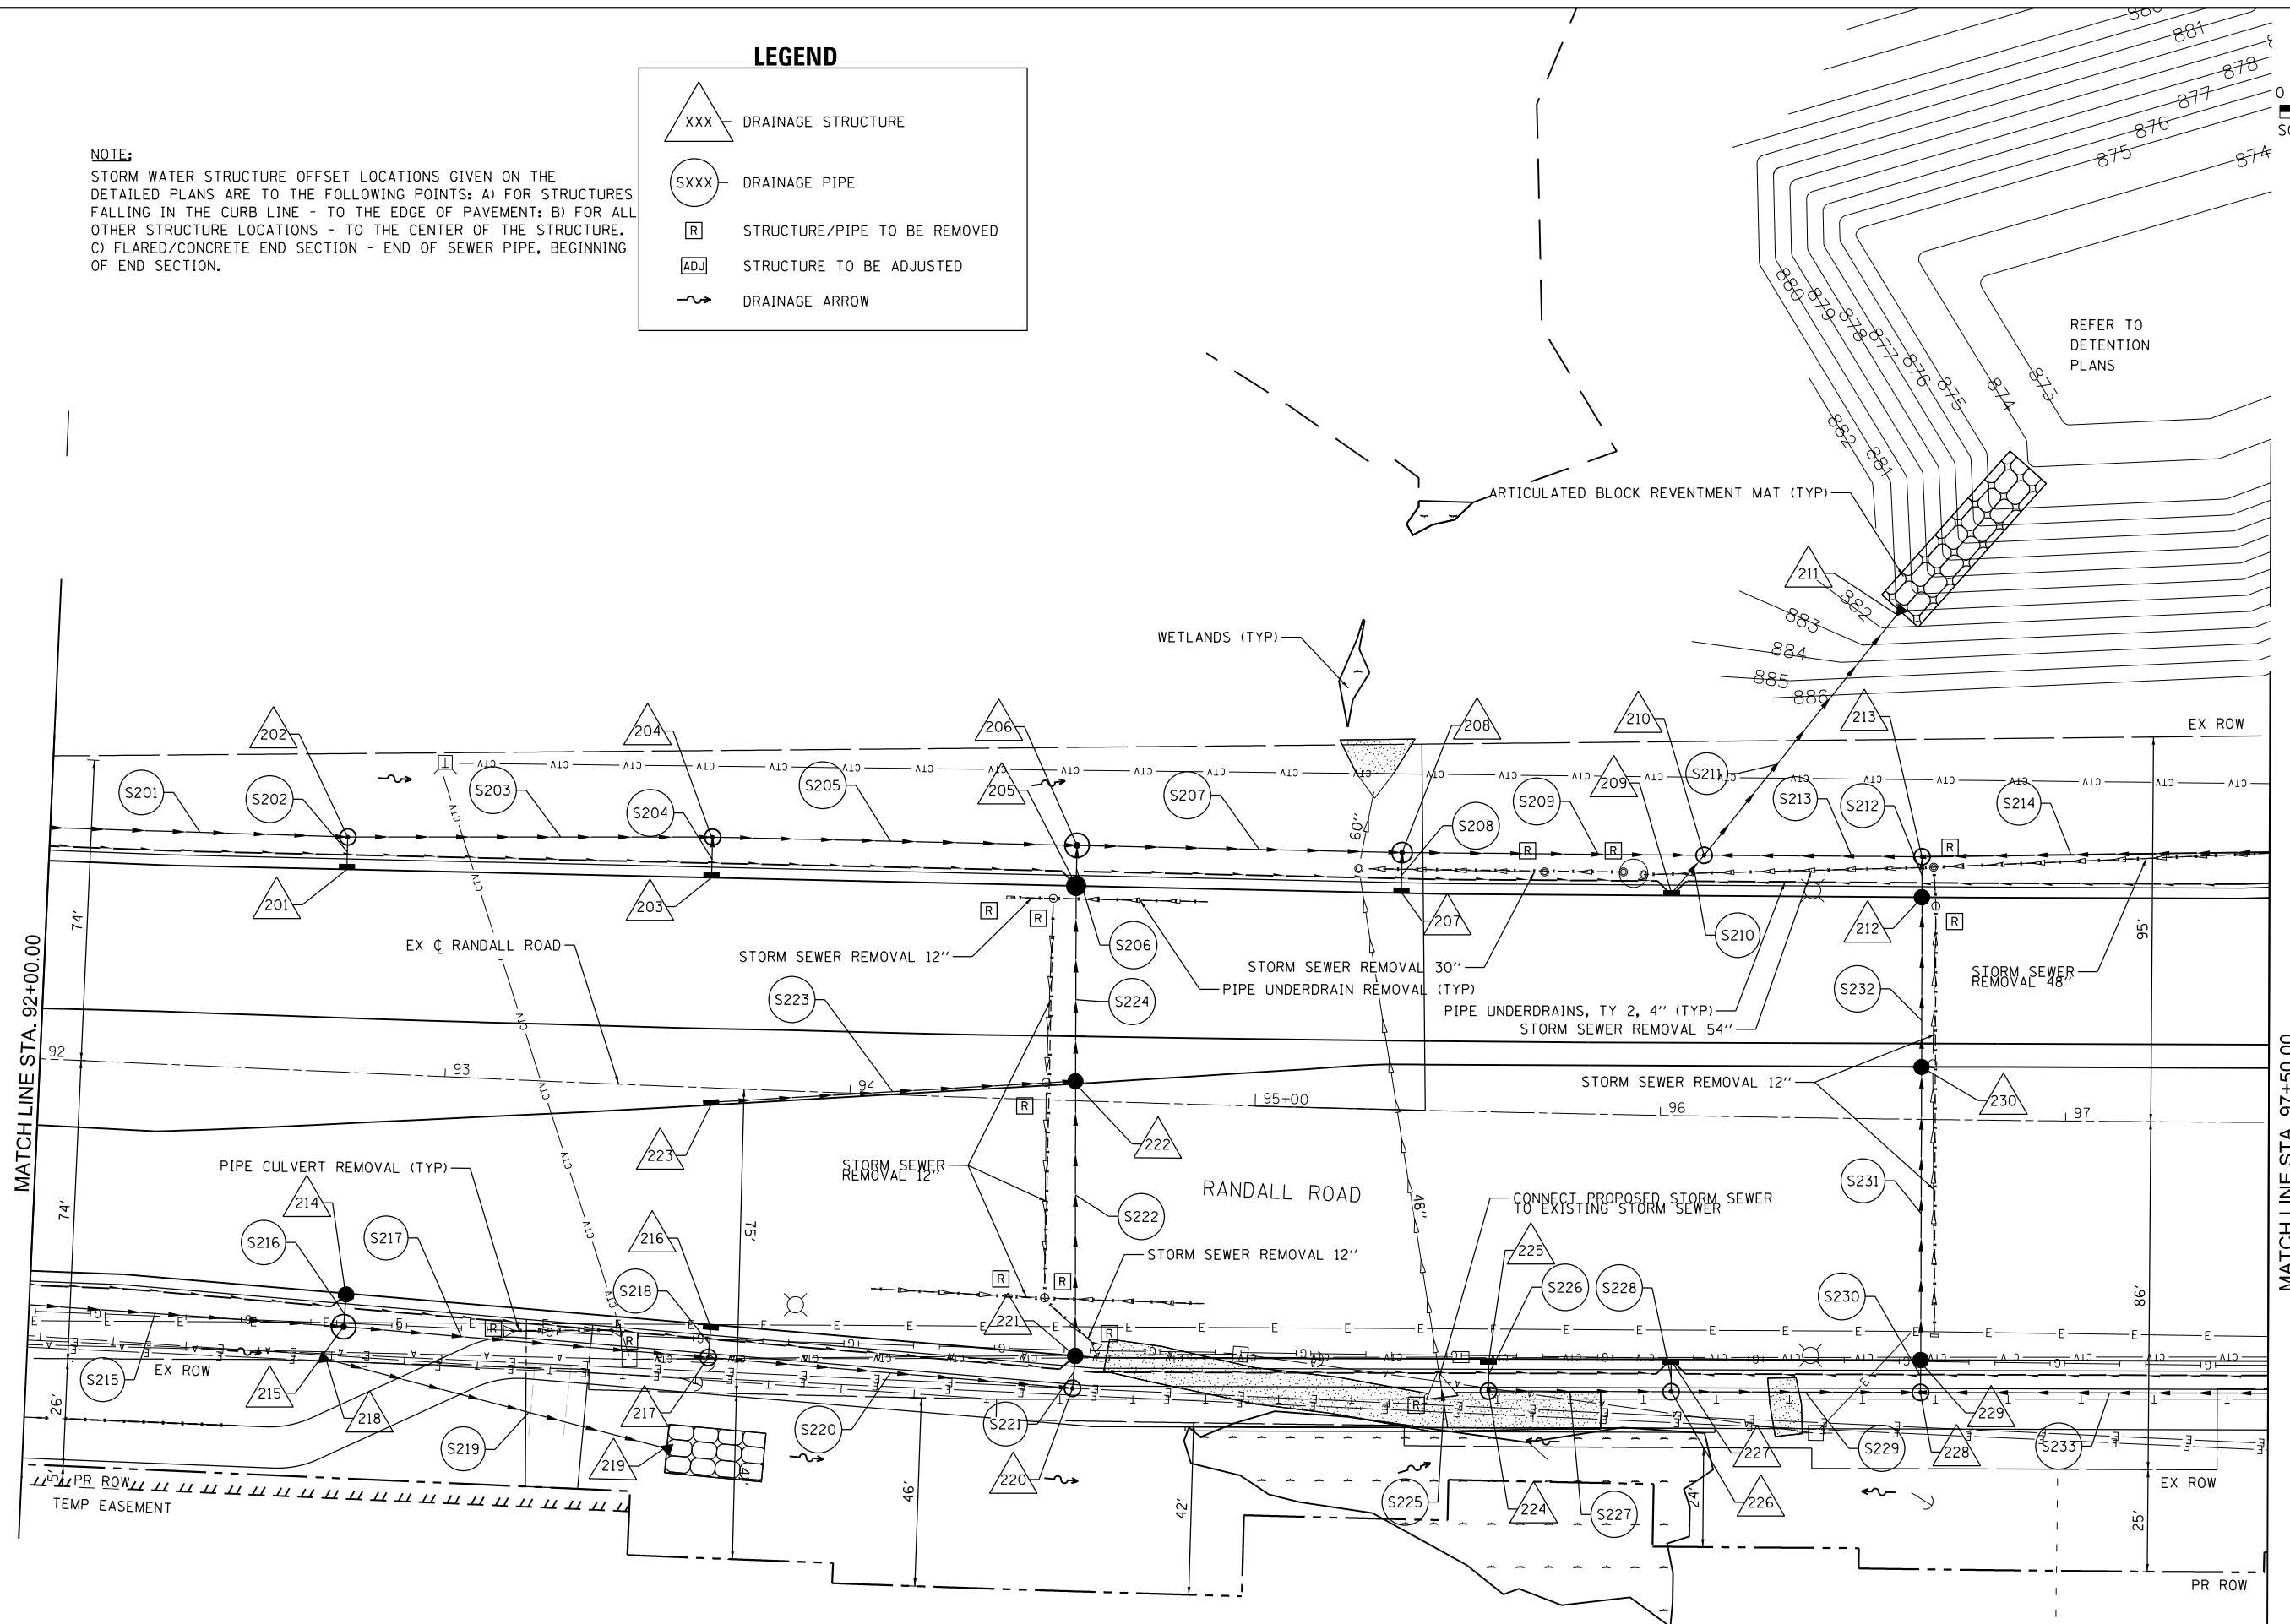

BLA, Inc.

USER NAME = cesario	DESIGNED - TN	REVISED -
PLOT SCALE = 48.0000' / in.	DRAWN - TN	REVISED -
PLOT DATE = 6/19/2025	CHECKED - GJE	REVISED -
	DATE - 02/15/2025	REVISED -


**STATE OF ILLINOIS
DEPARTMENT OF TRANSPORTATION**

**RANDALL ROAD AT IL ROUTE 72 (HIGGINS ROAD)
DRAINAGE AND UTILITY PLAN AND PROFILE**


SCALE: 1"=20' SHEET 4 OF 19 SHEETS STA. 92+00.00 TO STA. 97+50.00

F.A.P. RTE.	SECTION	COUNTY	TOTAL SHEETS	SHEET NO.
0336	19-00514-00-WR	KANE	304	104
CONTRACT NO. 61L28				
ILLINOIS FED. AID PROJECT				


PLAN	SURVEYED PLOTTED	CHECKED ALIGNED	DATE
NOTE BOOK NO.	CADD FILE NAME		

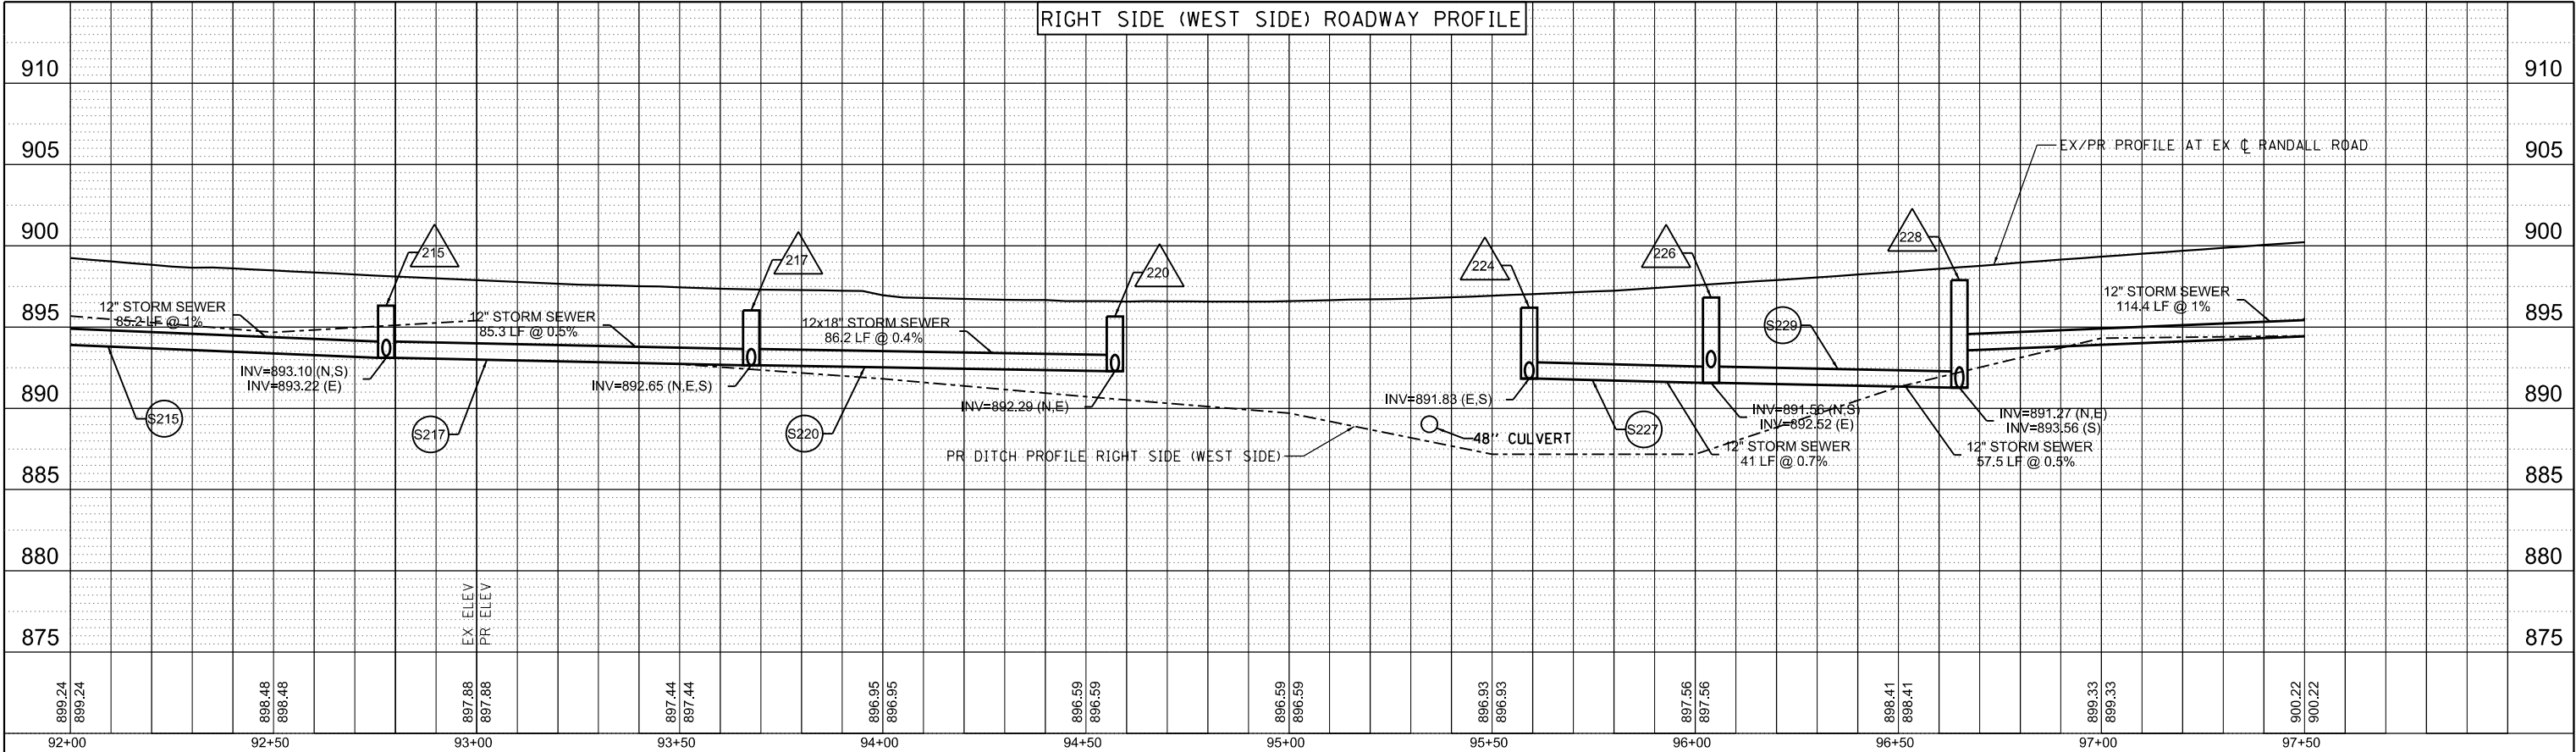

PROFILE	SURVEYED PLOTTED	CHECKED GRADES	DATE
NOTE BOOK NO.	CADD FILE NAME	NOT AT THIS CHKD	

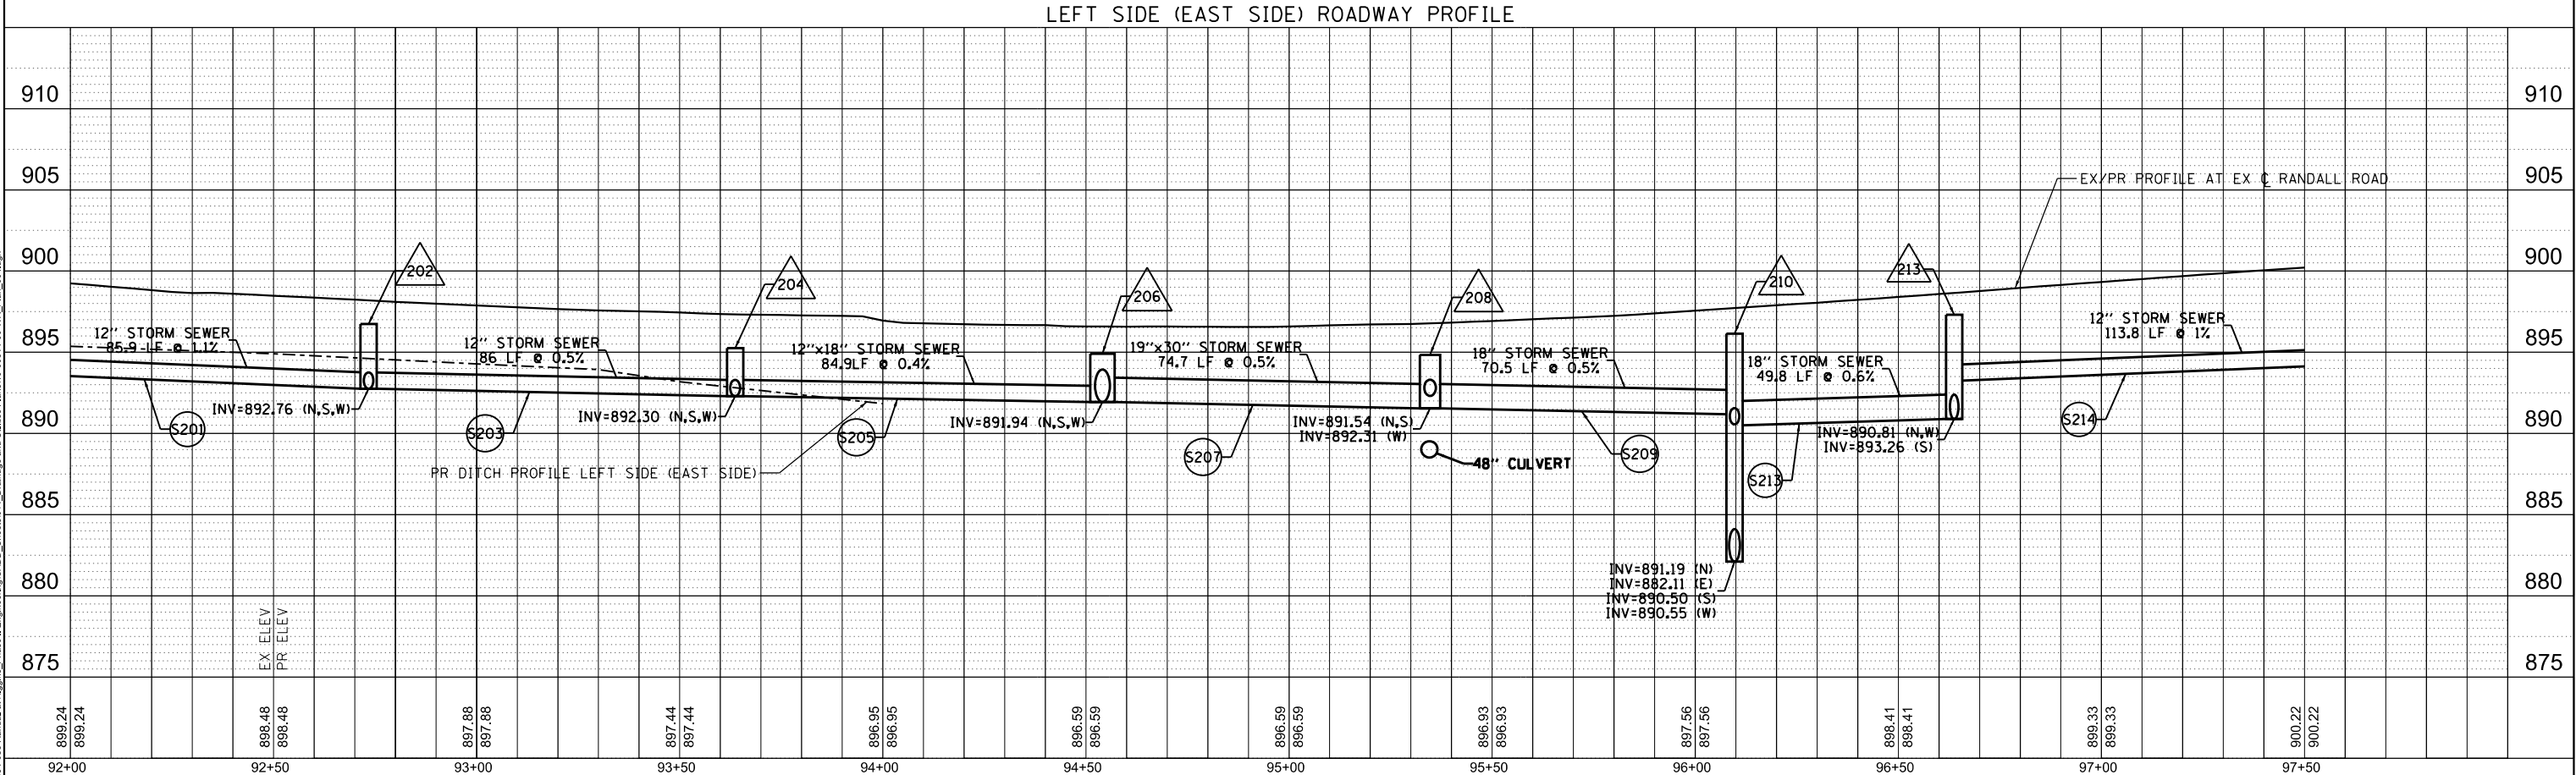


MODEL: DRAINAGE FILE NAME: 190336  BLA, Inc.	USER NAME = cesario	DESIGNED - TN	REVISED -	STATE OF ILLINOIS DEPARTMENT OF TRANSPORTATION	RANDALL ROAD AT IL ROUTE 72 (HIGGINS ROAD) DRAINAGE AND UTILITY PLAN AND PROFILE				F.A.P. RTE.	SECTION	COUNTY	TOTAL SHEETS	SHEET NO.
	PLOT SCALE = 40.0000' / in.	DRAWN - TN	REVISED -						0336	19-00514-00-WR	KANE	304	105
	PLOT DATE = 6/19/2025	CHECKED - GJE	REVISED -		CONTRACT NO. 61L28								
		DATE - 02/15/2025	REVISED -		ILLINOIS FED. AID PROJECT								
SCALE: 1"=20'		SHEET 5 OF 19 SHEETS		STA. 92+00.00 TO STA. 97+50.00									

 

IL ROUTE 72 (HIGGINS ROAD) (SEE SHEET 116)
MATCH LINE STA. 201+75.00

MATCH LINE STA. 97+50.00

MATCH LINE STA. 103+50.00

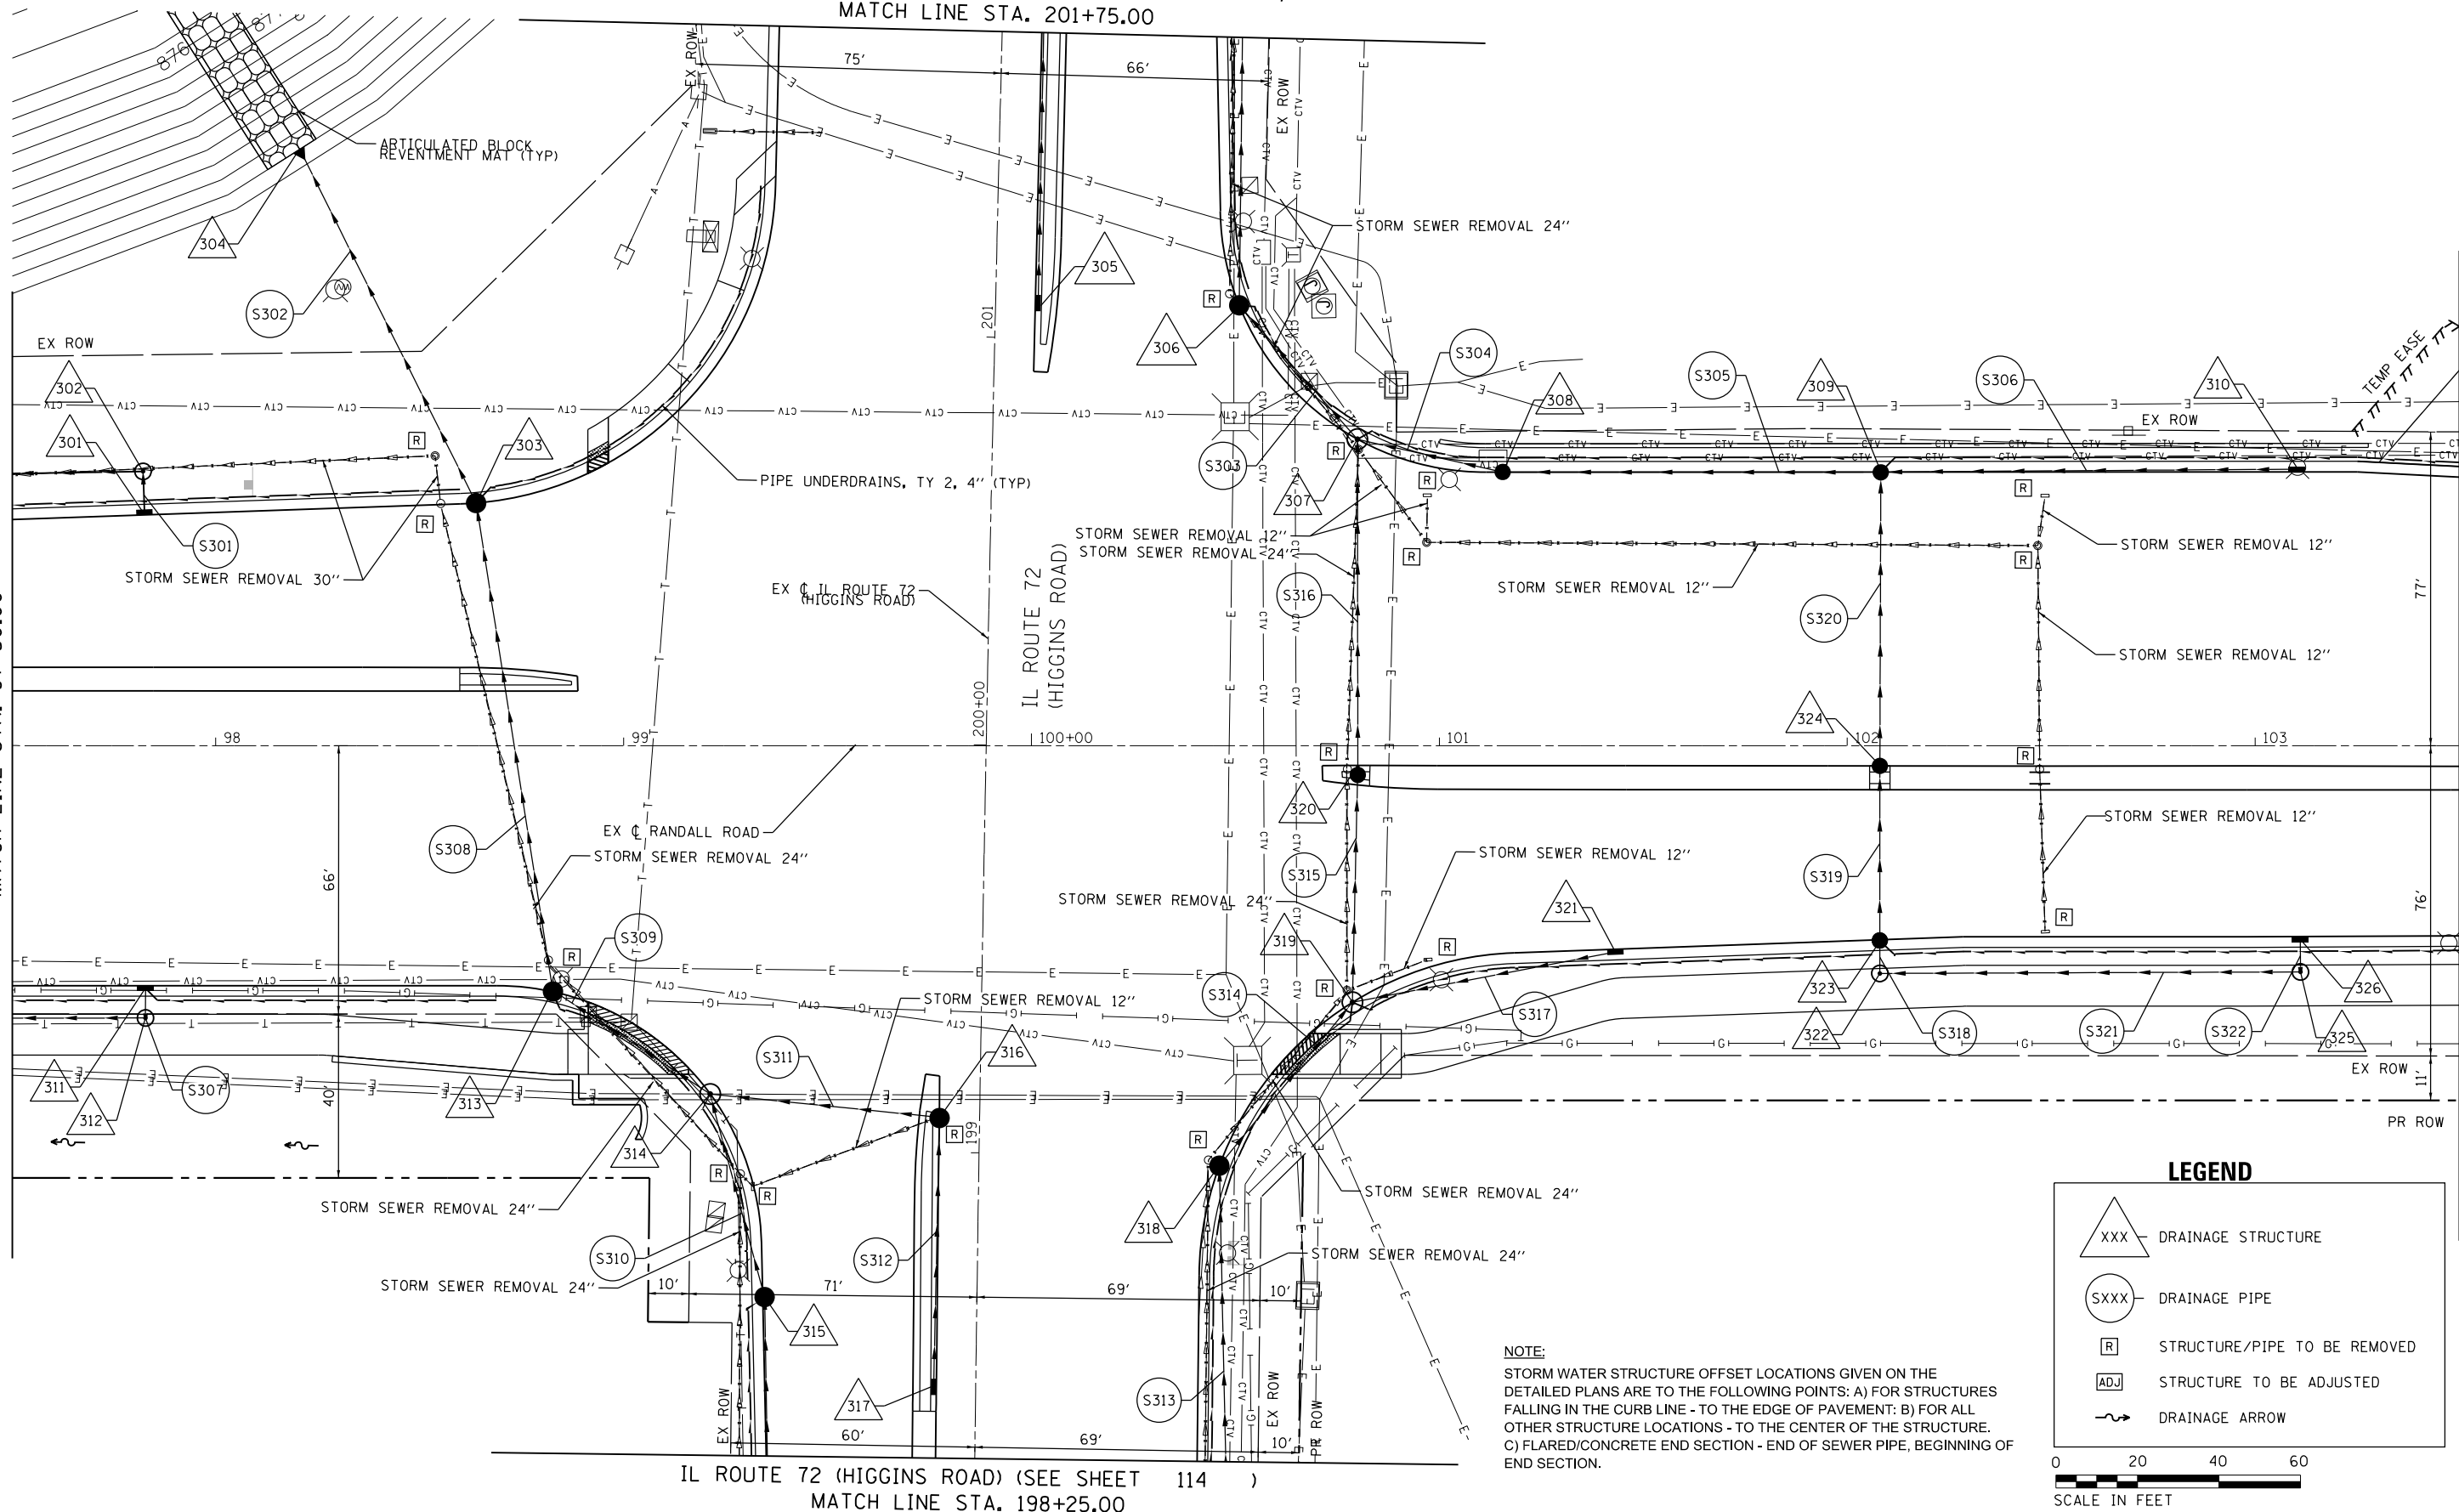

NOTE:
STORM WATER STRUCTURE OFFSET LOCATIONS GIVEN ON THE
DETAILED PLANS ARE TO THE FOLLOWING POINTS: A) FOR STRUCTURES
FALLING IN THE CURB LINE - TO THE EDGE OF PAVEMENT; B) FOR ALL
OTHER STRUCTURE LOCATIONS - TO THE CENTER OF THE STRUCTURE.
C) FLARED/CONCRETE END SECTION - END OF SEWER PIPE, BEGINNING OF
END SECTION.

LEGEND

- XXX - DRAINAGE STRUCTURE
- SXXX - DRAINAGE PIPE
- [R] - STRUCTURE/PIPE TO BE REMOVED
- [ADJ] - STRUCTURE TO BE ADJUSTED
- ~ - DRAINAGE ARROW

0 20 40 60
SCALE IN FEET

IL ROUTE 72 (HIGGINS ROAD) (SEE SHEET 114)
MATCH LINE STA. 198+25.00



BLA, Inc.

USER NAME = cesario	DESIGNED - TN	REVISED -
PLOT SCALE = 48.0000' / in.	DRAWN - TN	REVISED -
PLOT DATE = 6/19/2025	CHECKED - GJE	REVISED -
	DATE - 02/15/2025	REVISED -


STATE OF ILLINOIS
DEPARTMENT OF TRANSPORTATION

RANDALL ROAD AT IL ROUTE 72 (HIGGINS ROAD)
DRAINAGE AND UTILITY PLAN AND PROFILE


SCALE: 1"=20' SHEET 6 OF 19 SHEETS STA. 97+50.00 TO STA. 103+50.00

F.A.P. RTE.	SECTION	COUNTY	TOTAL SHEETS	SHEET NO.
0336	19-00514-00-WR	KANE	304	106
CONTRACT NO. 61L28				
ILLINOIS FED. AID PROJECT				

PLAN	SURVEYED	BY	DATE
NOTE BOOK	CHECKED	NO.	CADD FILE NAME

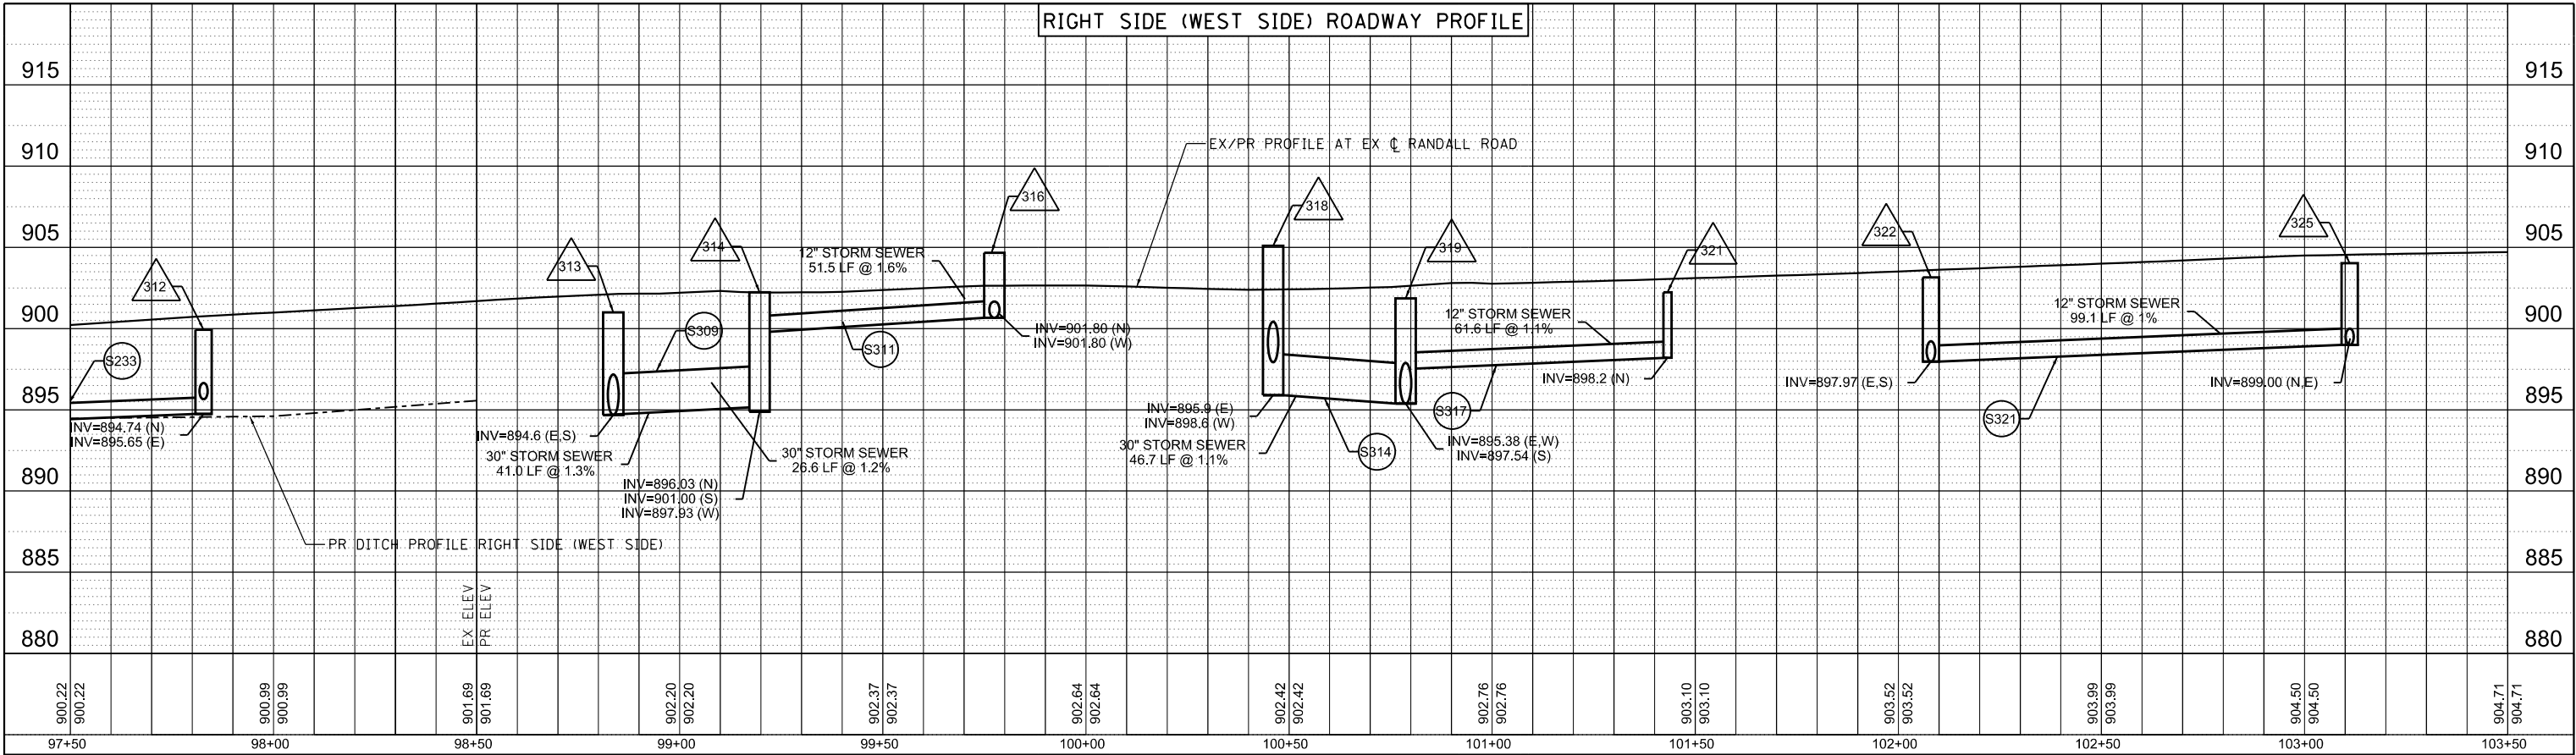

PROFILE	SURVEYED	BY	DATE
NOTE BOOK	CHECKED	NO.	NOT AT THIS CHKD

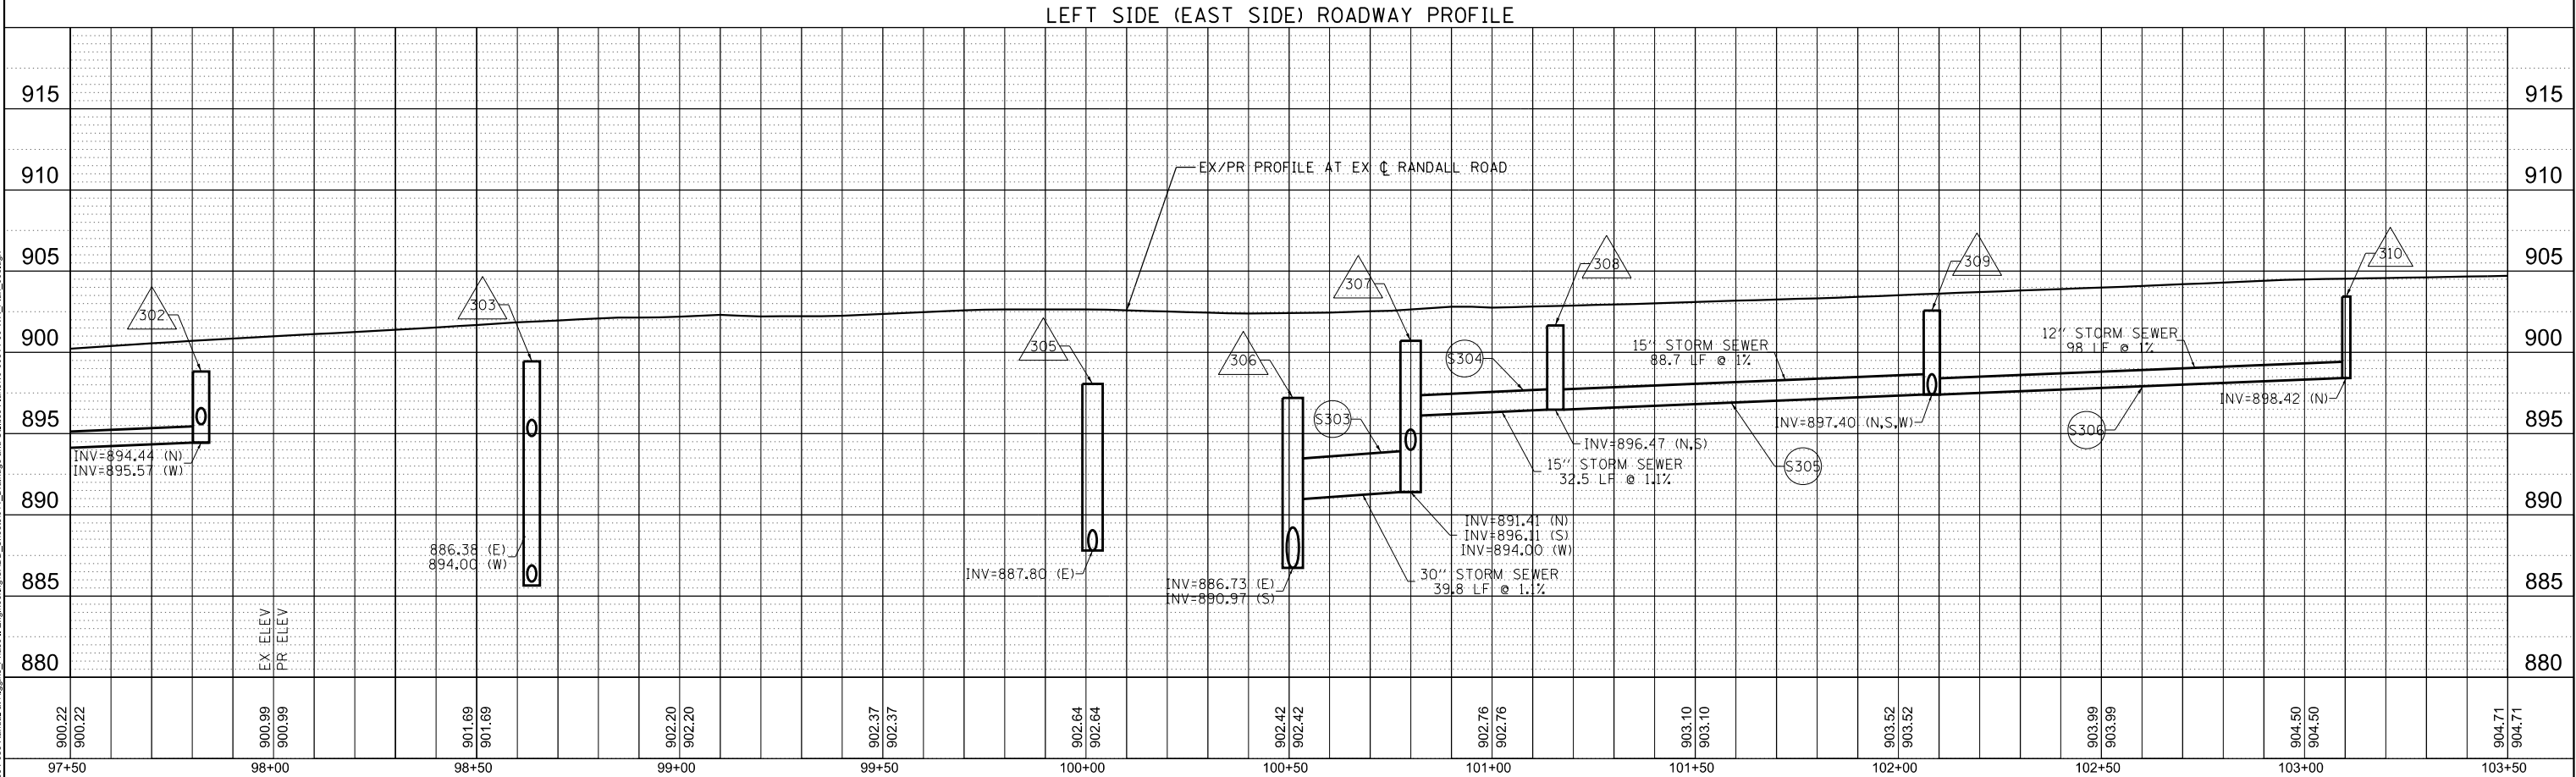

MODEL: Default
FILE NAME: W8894-088.Randall at Higgins Phase II Engineering\cadd Sheets\011 Drainage and Utilities Plans\894-088-WR Plan_005.dgn



USER NAME : cesario	DESIGNED - TN	REVISED -
	DRAWN - TN	REVISED -
PLOT SCALE = 40.0000' / in.	CHECKED - GJE	REVISED -
PLOT DATE = 6/19/2025	DATE - 02/15/2025	REVISED -

STATE OF ILLINOIS
DEPARTMENT OF TRANSPORTATION

RANDALL ROAD AT IL ROUTE 72 (HIGGINS ROAD)
DRAINAGE AND UTILITY PLAN AND PROFILE

SCALE: 1"=20' SHEET 7 OF 19 SHEETS STA. 97+50.00 TO STA. 103+50.00

F.A.P. RTE.	SECTION	COUNTY	TOTAL SHEETS	SHEET NO.
0336	19-00514-00-WR	KANE	304	107
CONTRACT NO. 61L28				
ILLINOIS FED. AID PROJECT				

MODEL: Default
FILE NAME: V:\0994-088 Randall at Higgins Phase II Engineering\CADD Sheets\011 Drainage and Utilities Plans\19-00514-00-WR Plan_007.dgn



BLA, Inc.


USER NAME = cesario	DESIGNED - TN	REVISED -
	DRAWN - TN	REVISED -
PLOT SCALE = 48.0000' / in.	CHECKED - GJE	REVISED -
PLOT DATE = 6/19/2025	DATE - 02/15/2025	REVISED -

STATE OF ILLINOIS
DEPARTMENT OF TRANSPORTATION

RANDALL ROAD AT IL ROUTE 72 (HIGGINS ROAD)
DRAINAGE AND UTILITY PLAN AND PROFILE

SCALE: 1"=20' SHEET 8 OF 19 SHEETS STA. 103+50.00 TO STA. 109+50.00

F.A.P. RTE. 0336	SECTION 19-00514-00-WR	COUNTY KANE	TOTAL SHEETS 304	SHEET NO. 108
CONTRACT NO. 61L28				
ILLINOIS FED. AID PROJECT				

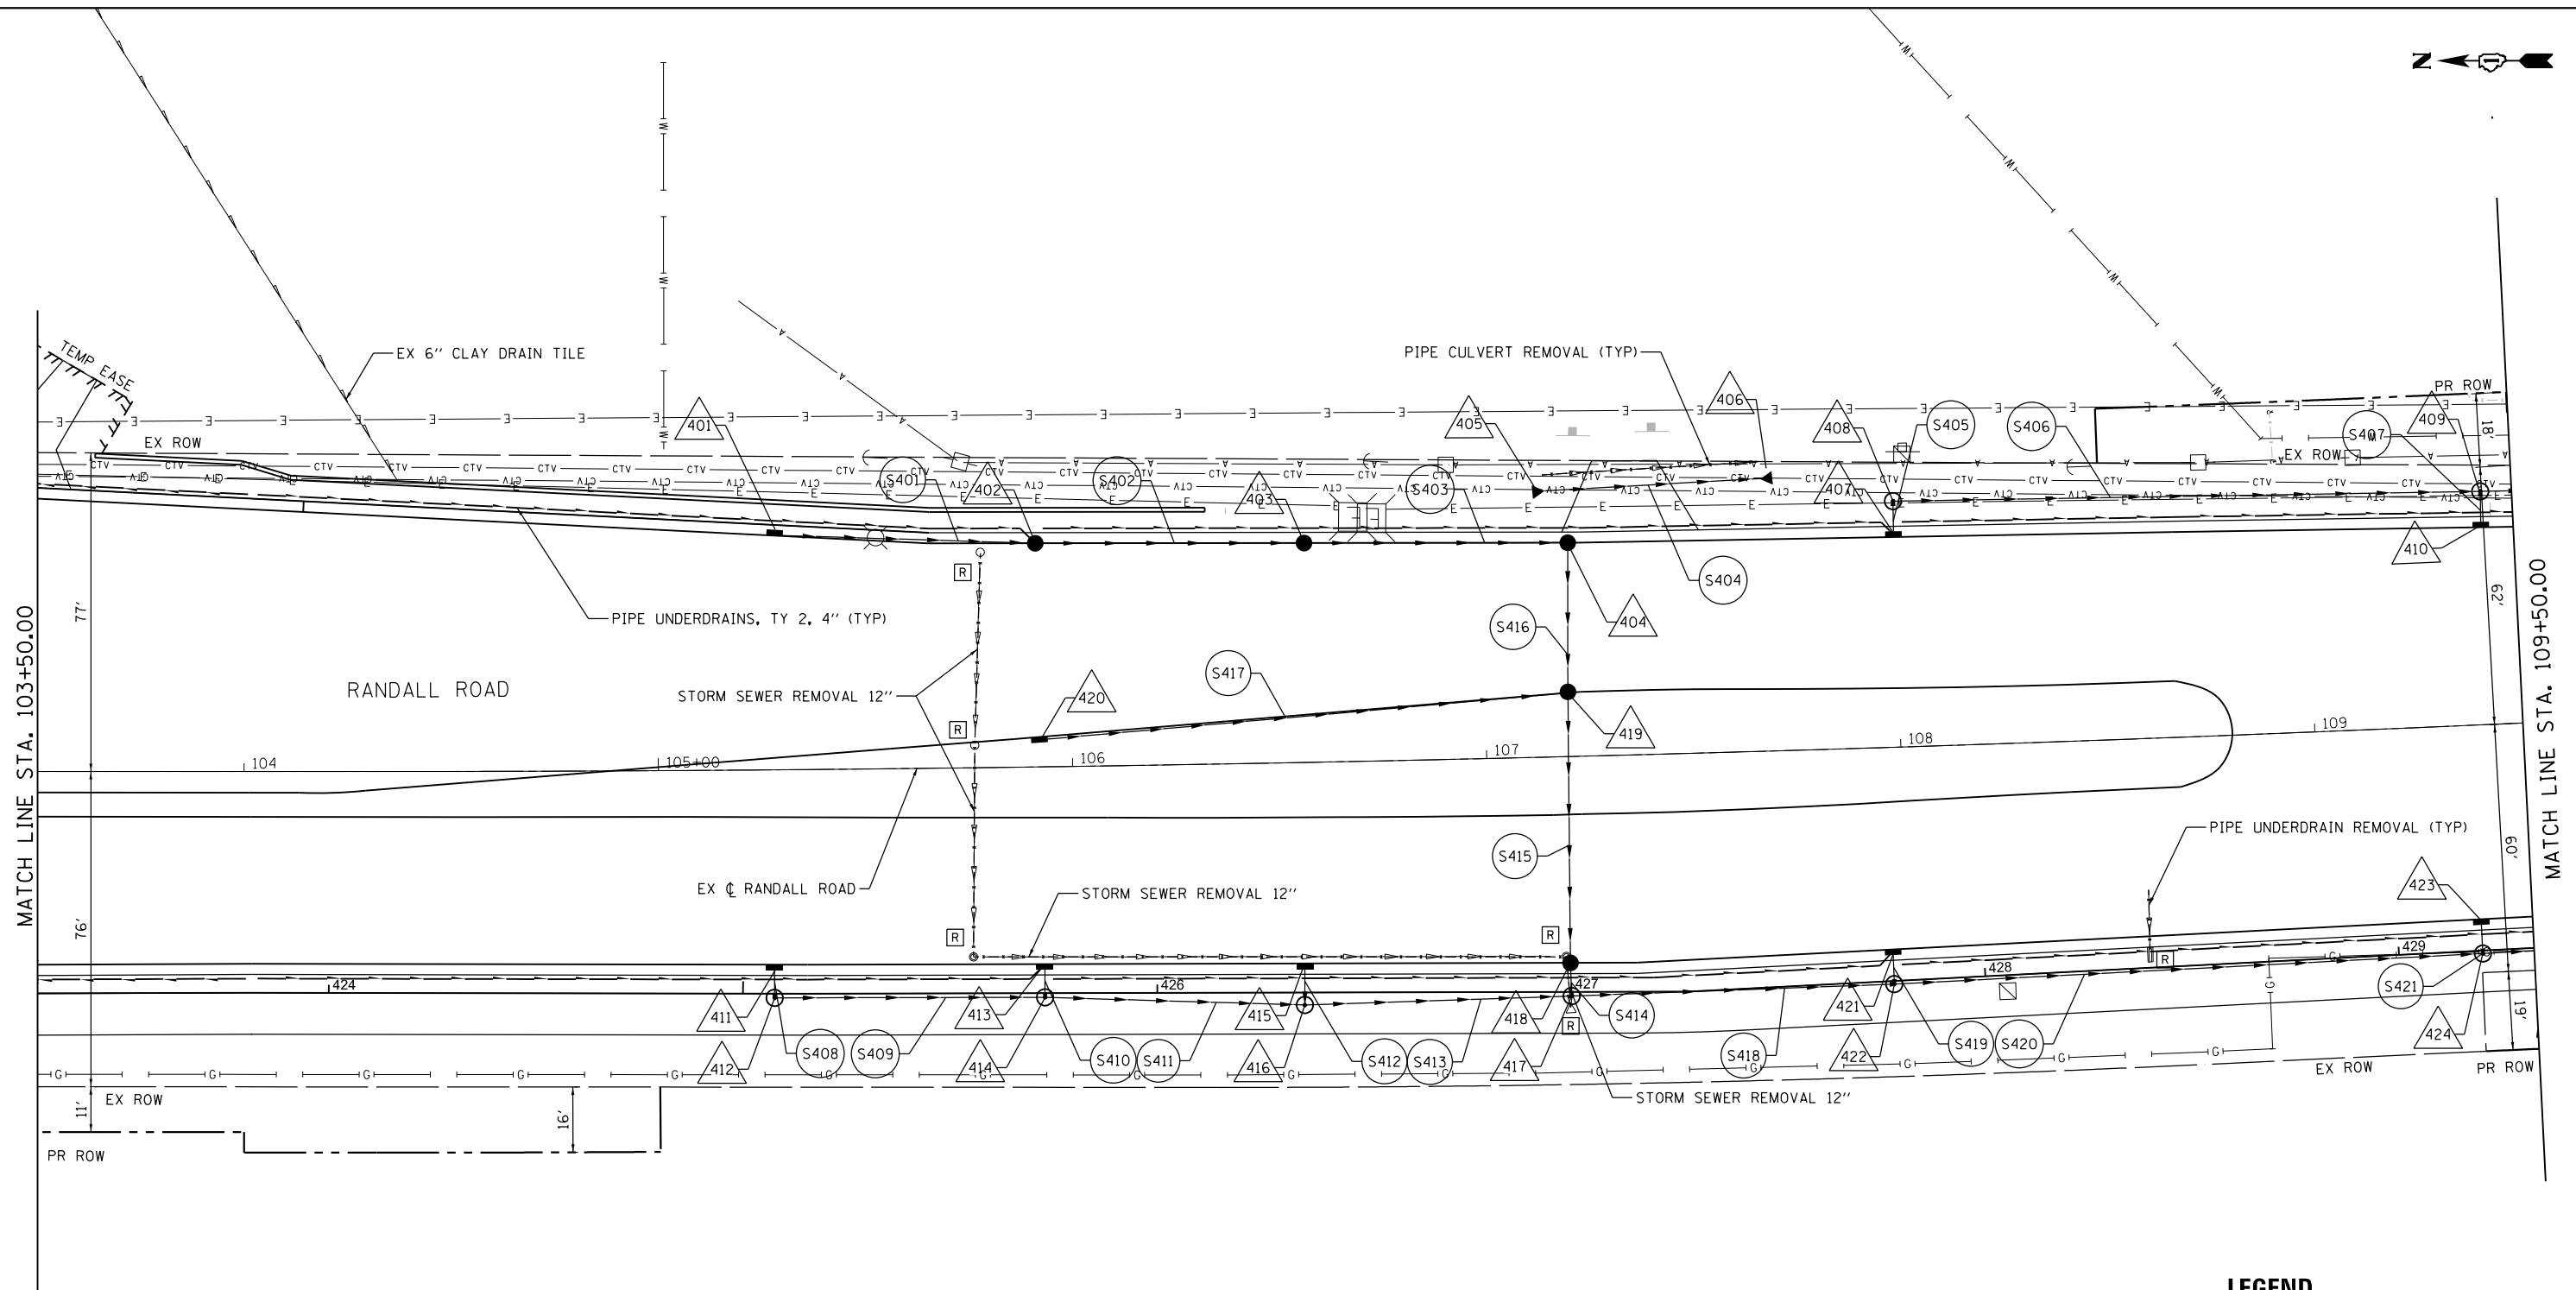


LEGEND

XXX	DRAINAGE STRUCTURE
SXXX	DRAINAGE PIPE
[R]	STRUCTURE/PIPE TO BE REMOVED
[ADJ]	STRUCTURE TO BE ADJUSTED
~>	DRAINAGE ARROW




NOTE:
STORM WATER STRUCTURE OFFSET LOCATIONS GIVEN ON THE
DETAILED PLANS ARE TO THE FOLLOWING POINTS: A) FOR STRUCTURES
FALLING IN THE CURB LINE - TO THE EDGE OF PAVEMENT; B) FOR ALL
OTHER STRUCTURE LOCATIONS - TO THE CENTER OF THE STRUCTURE.
C) FLARED/CONCRETE END SECTION - END OF SEWER PIPE, BEGINNING OF
END SECTION.

PLAN	SURVEYED PLOTTED	BY	DATE
NOTE BOOK NO.	CHECKED DATE	FILE NAME	CADD FILE NAME

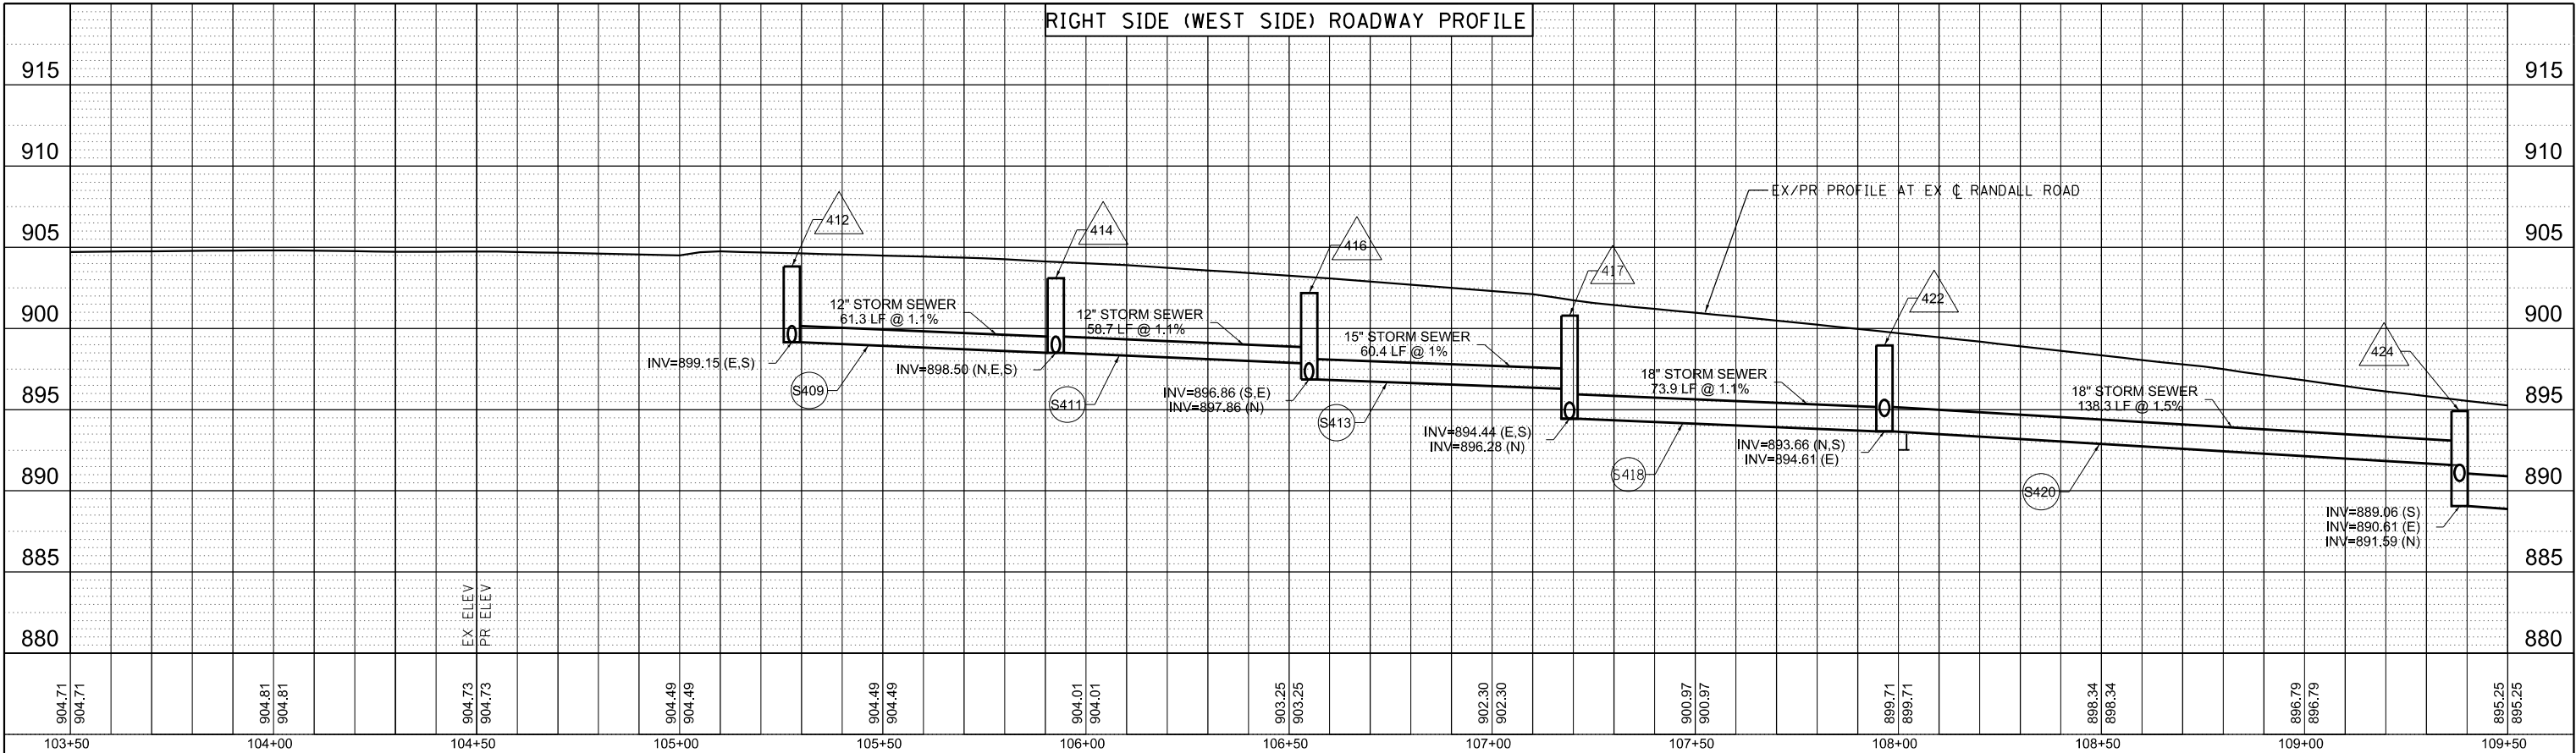

PROFILE	SURVEYED PLOTTED	BY	DATE
NOTE BOOK NO.	CHECKED DATE	FILE NAME	CADD FILE NAME

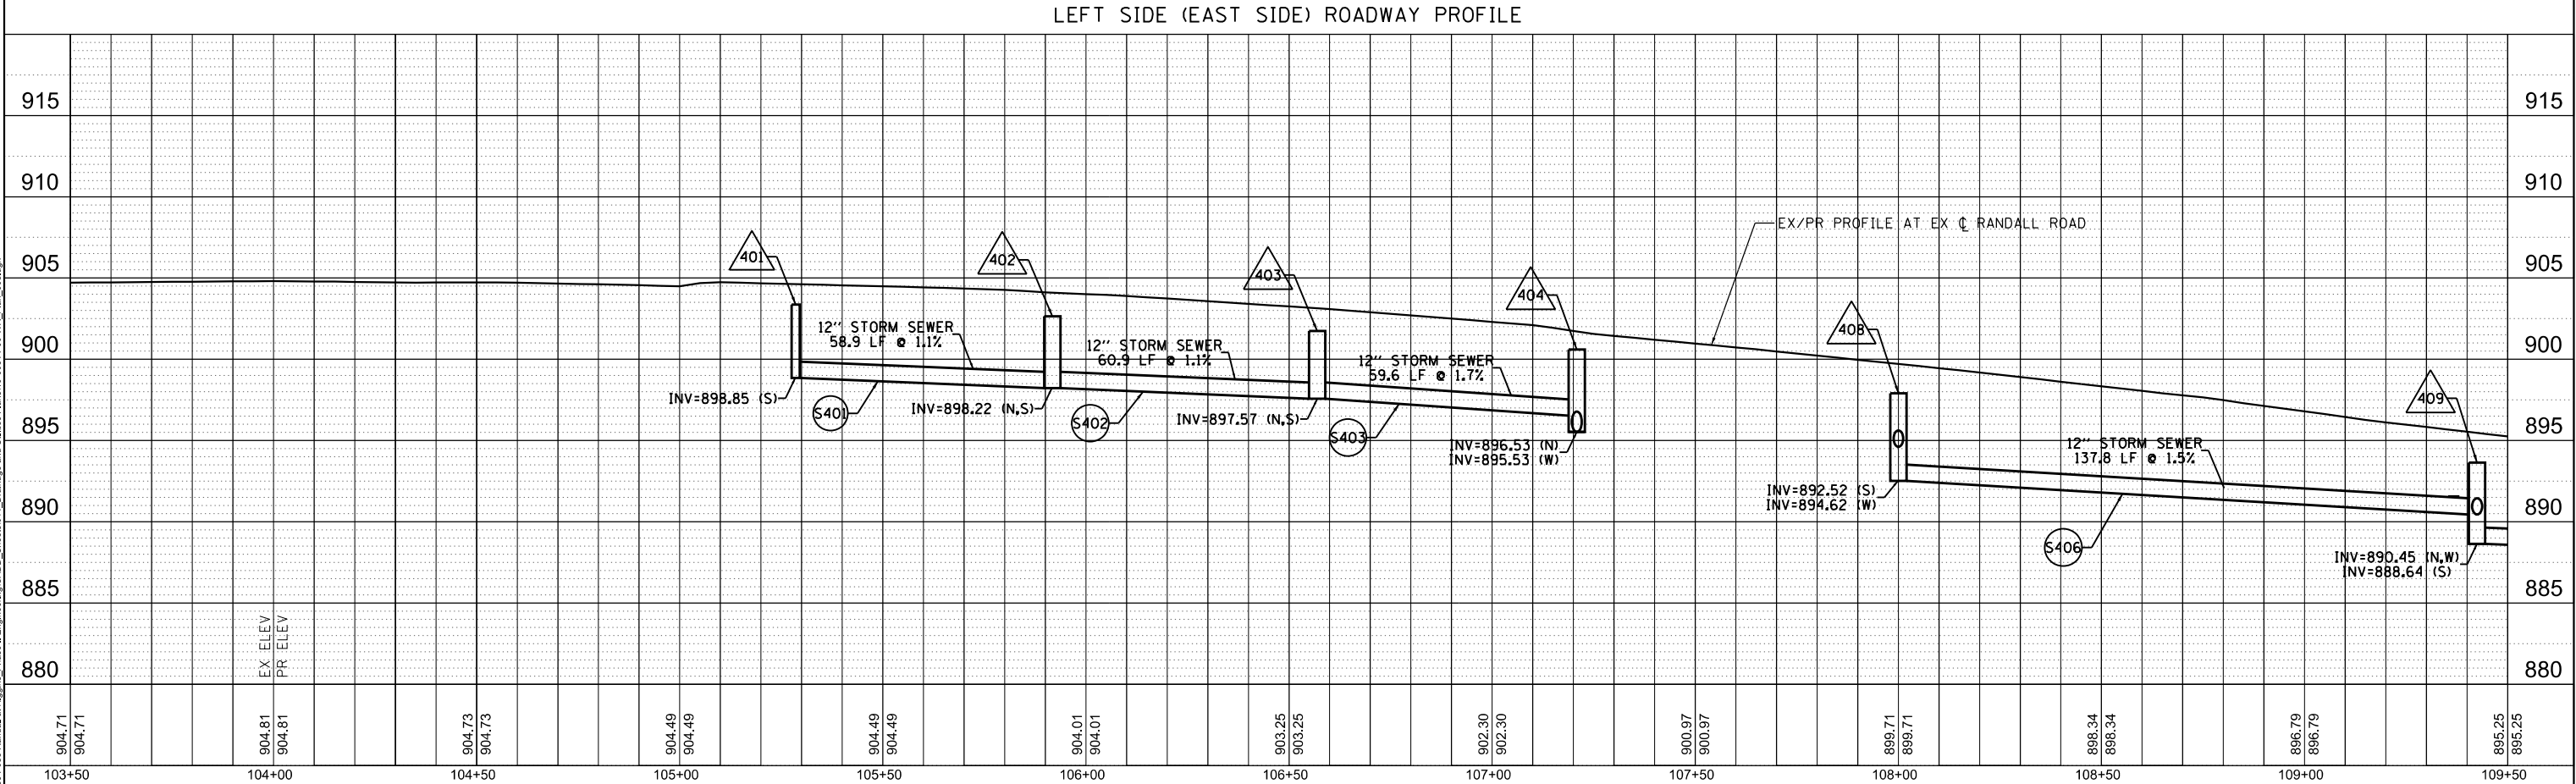

MODEL: Default
FILE NAME: W:\894-088 Randall at Higgins Phase II Engineering\CADD Sheets\011 Drainage and Utilities Plans\540514-00-WR Plan_005.dgn



BLA, Inc.

USER NAME : cesario	DESIGNED - TN	REVISED -
	DRAWN - TN	REVISED -
PLOT SCALE : 40.0000' / in.	CHECKED - GJE	REVISED -
PLOT DATE : 6/19/2025	DATE - 02/15/2025	REVISED -

STATE OF ILLINOIS
DEPARTMENT OF TRANSPORTATION

RANDALL ROAD AT IL ROUTE 72 (HIGGINS ROAD)
DRAINAGE AND UTILITY PLAN AND PROFILE

SCALE: 1"=20' SHEET 9 OF 19 SHEETS STA. 107+50.00 TO STA. 113+50.00

F.A.P. RTE.	SECTION	COUNTY	TOTAL SHEETS	SHEET NO.
0336	19-00514-00-WR	KANE	304	109
CONTRACT NO. 61L28				
ILLINOIS FED. AID PROJECT				

MODEL: Default
FILE NAME: W:\894-088 Randall at Higgins Phase II Engineering\CADD Sheets\011 Drainage and Utilities Plans\18-00514-00-WR Plan_009.dgn



BLA, Inc.

USER NAME = cesario	DESIGNED - TN	REVISED -
PLOT SCALE = 48.0000' / in.	DRAWN - TN	REVISED -
PLOT DATE = 6/19/2025	CHECKED - GJE	REVISED -
	DATE - 02/15/2025	REVISED -


STATE OF ILLINOIS
DEPARTMENT OF TRANSPORTATION

RANDALL ROAD AT IL ROUTE 72 (HIGGINS ROAD)
DRAINAGE AND UTILITY PLAN AND PROFILE

SCALE: 1"=20' SHEET 10 OF 19 SHEETS STA. 95+50.00 TO STA. 101+50.00


F.A.P. RTE.	SECTION	COUNTY	TOTAL SHEETS	SHEET NO.
0336	19-00514-00-WR	KANE	304	110
CONTRACT NO. 61L28				
ILLINOIS FED. AID PROJECT				

MATCH LINE STA. 109+50.00

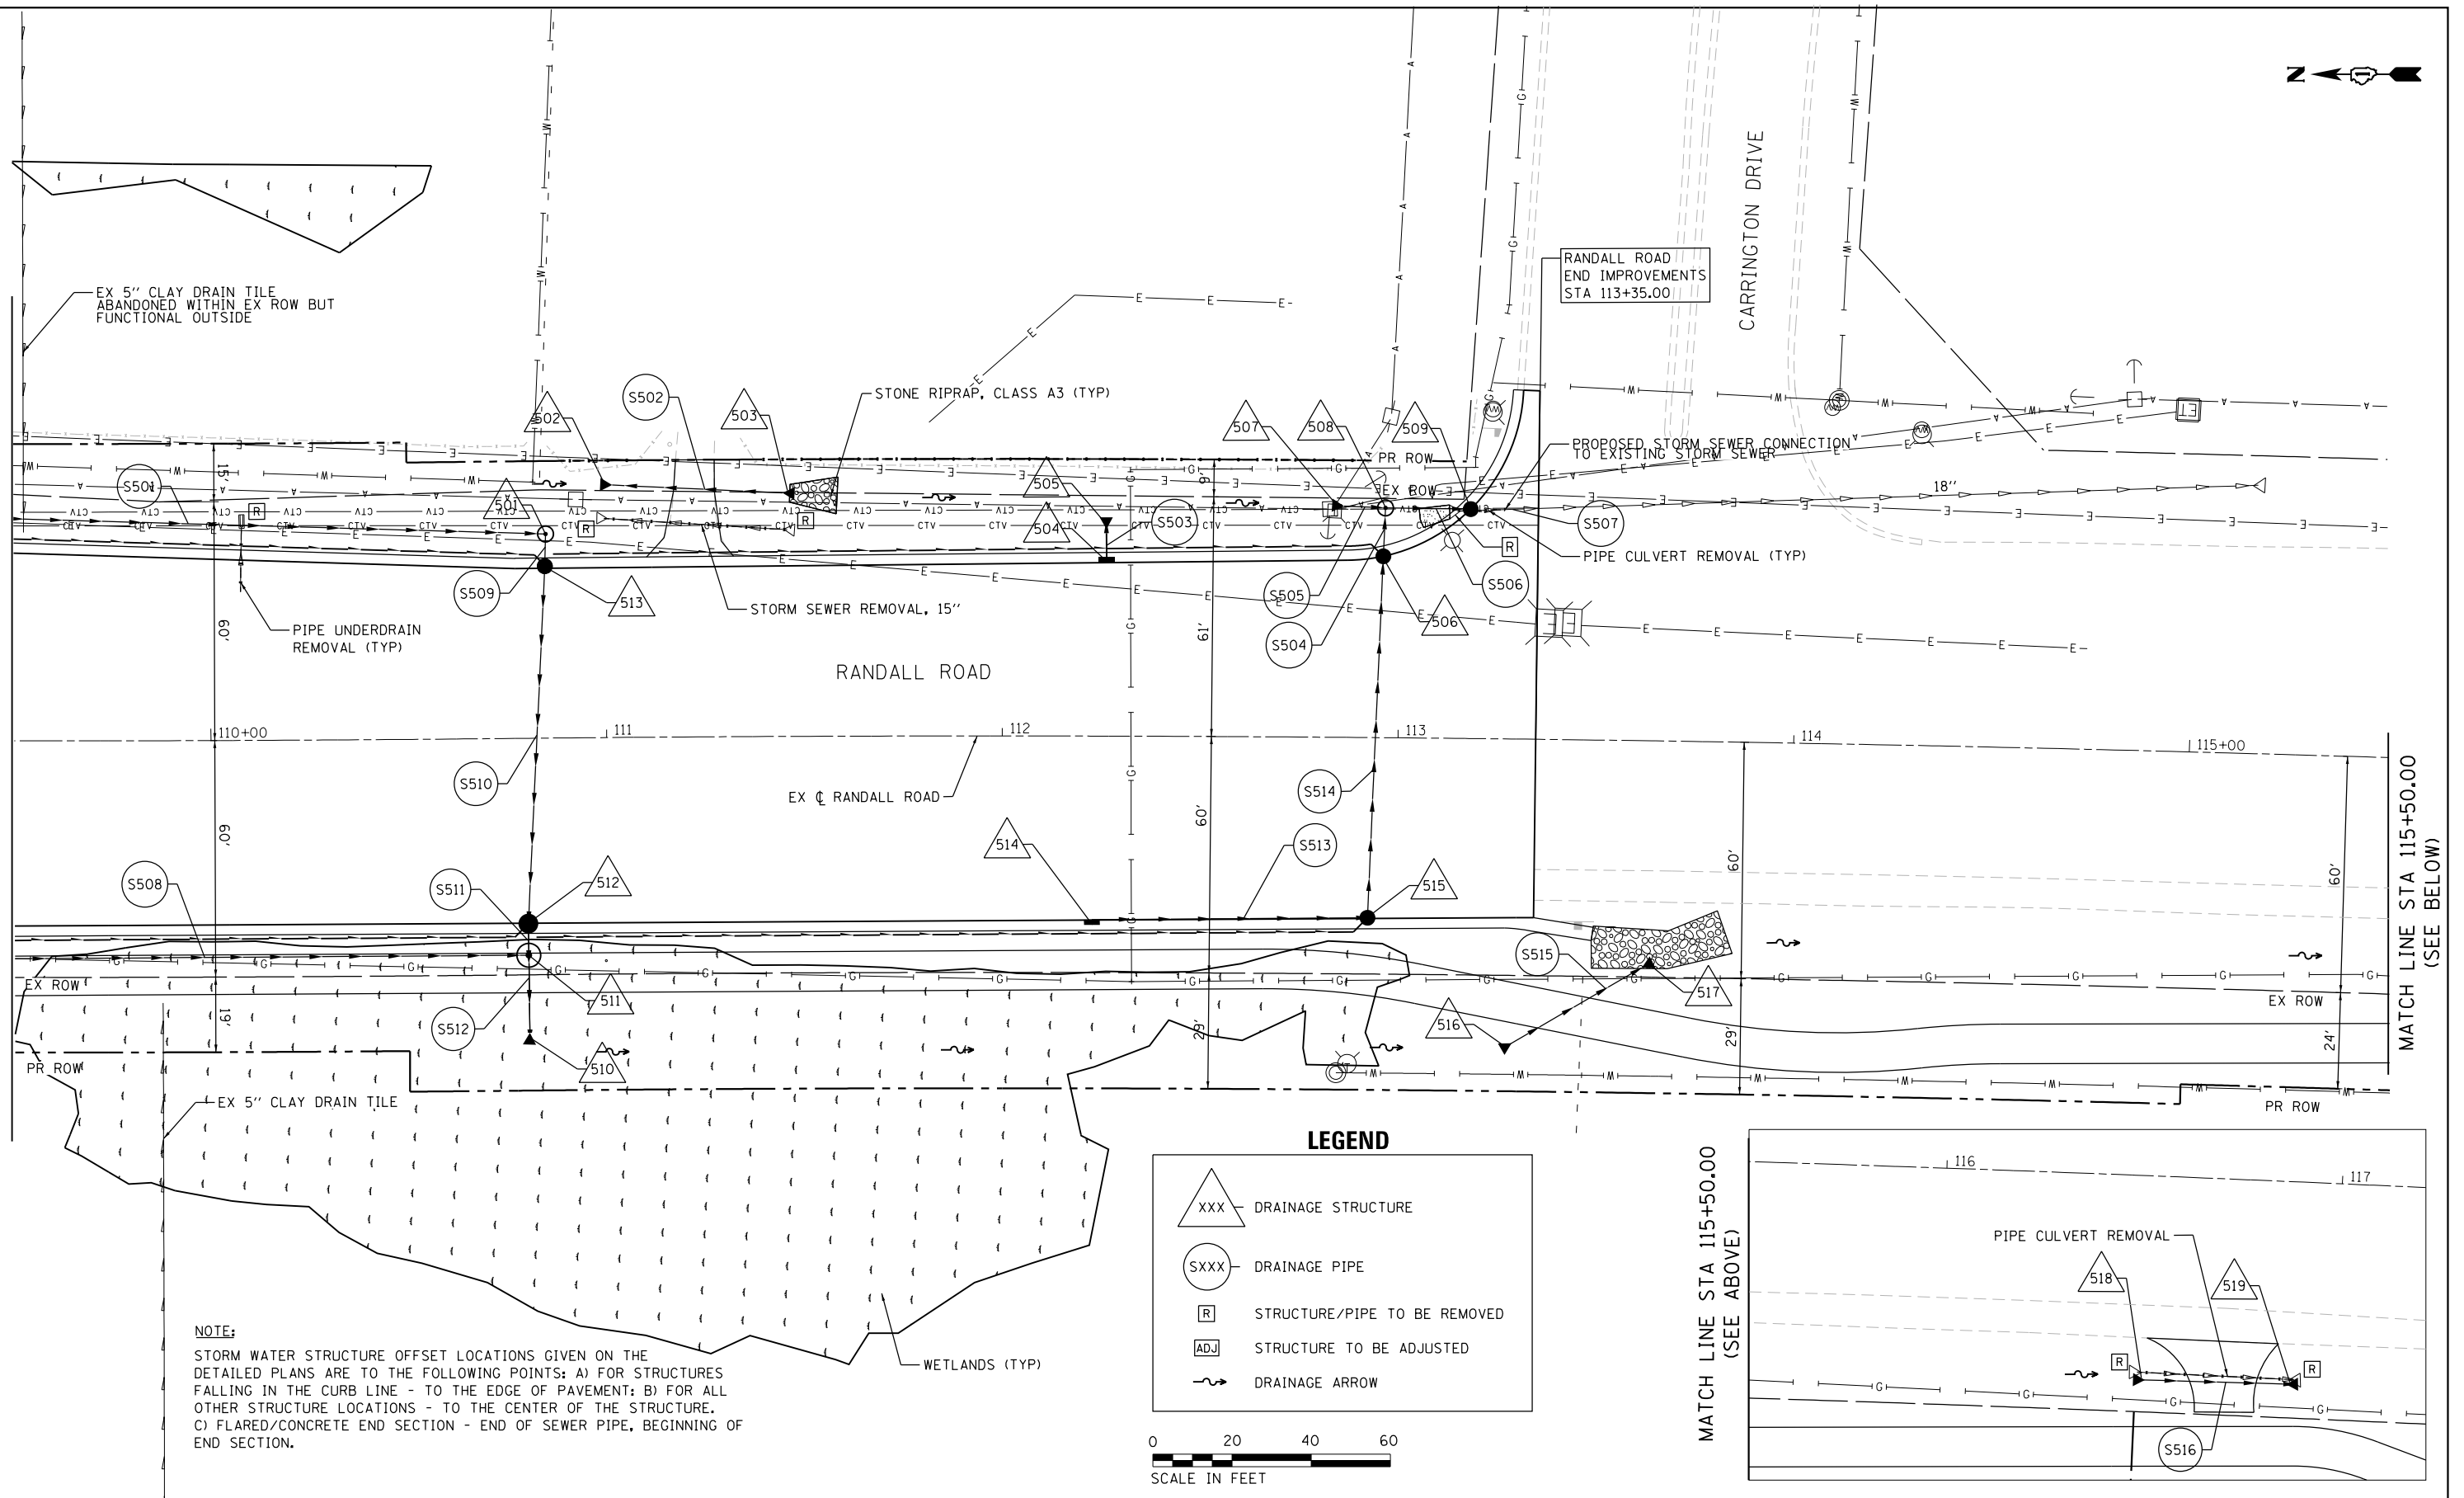


NOTE:
STORM WATER STRUCTURE OFFSET LOCATIONS GIVEN ON THE DETAILED PLANS ARE TO THE FOLLOWING POINTS: A) FOR STRUCTURES FALLING IN THE CURB LINE - TO THE EDGE OF PAVEMENT; B) FOR ALL OTHER STRUCTURE LOCATIONS - TO THE CENTER OF THE STRUCTURE. C) FLARED/CONCRETE END SECTION - END OF SEWER PIPE, BEGINNING OF END SECTION.

PLAN	SURVEYED	BY	DATE
	PLOTTED		
NOTE BOOK NO.	CHECKED		
	FILE NAME		

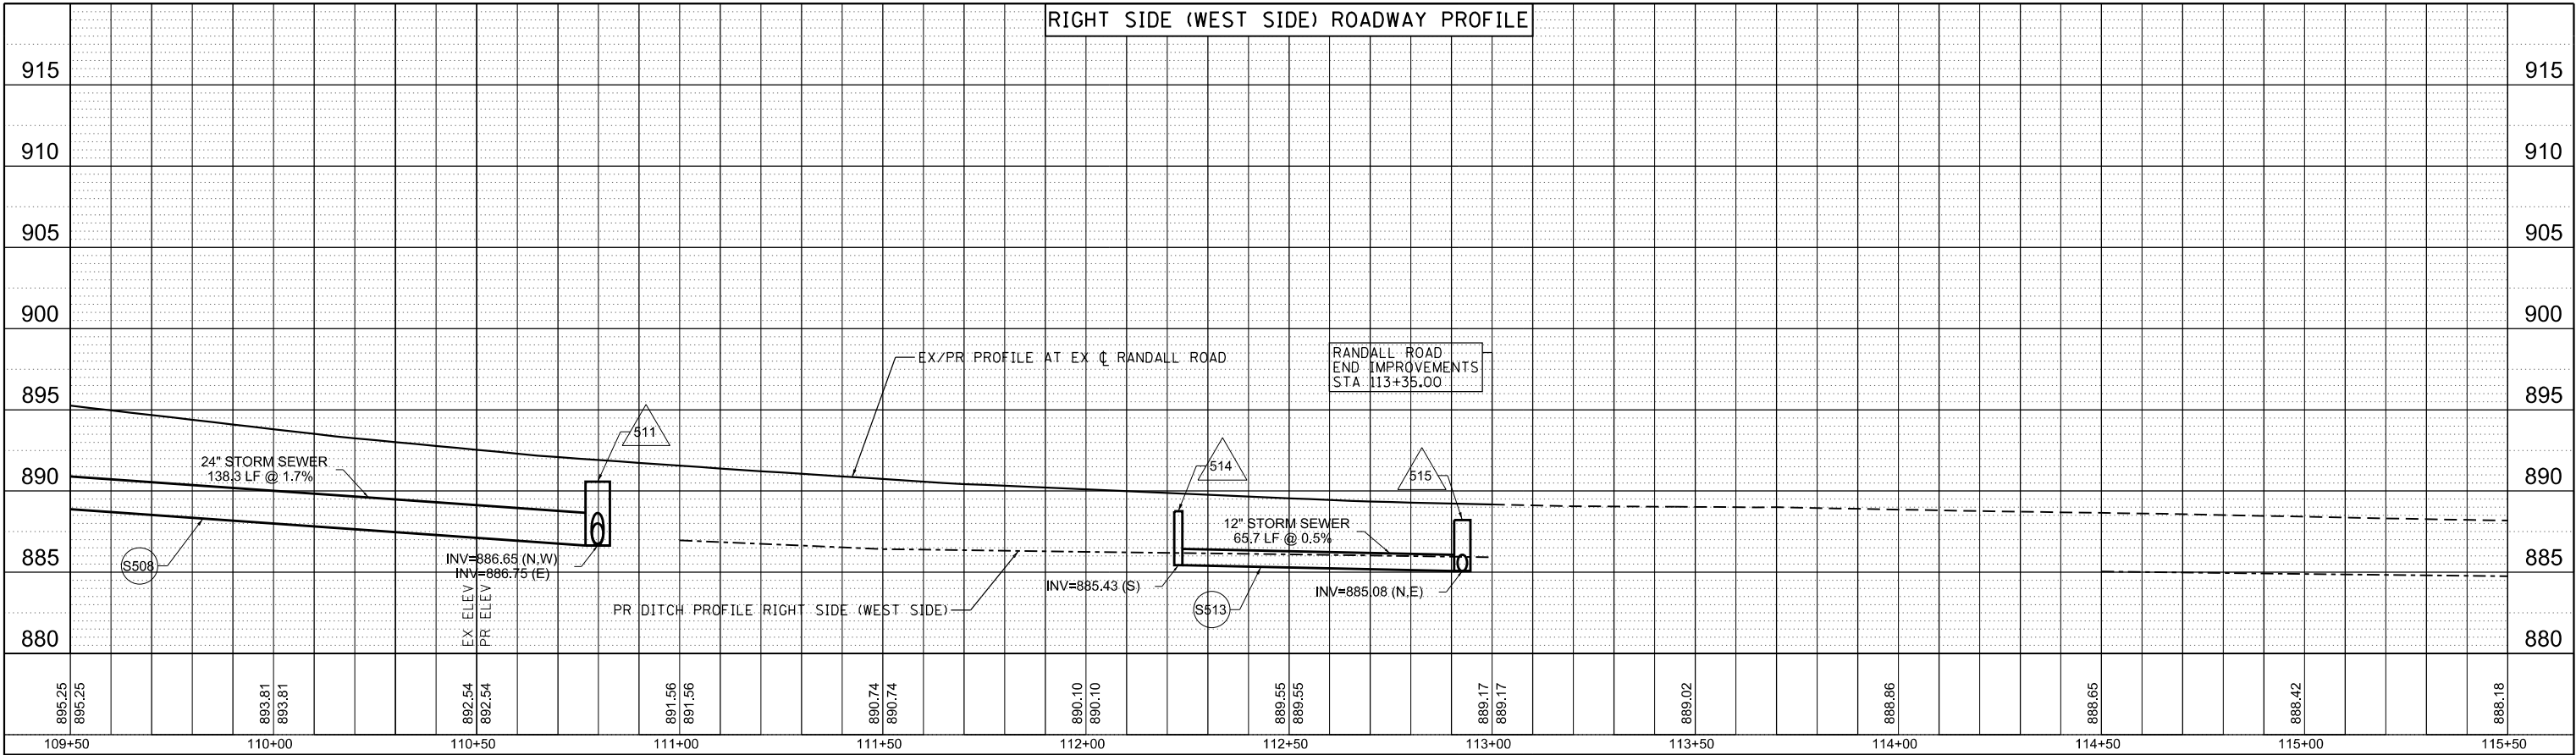

PROFILE	SURVEYED	BY	DATE
	PLOTTED		
NOTE BOOK NO.	CHECKED		
	FILE NAME		

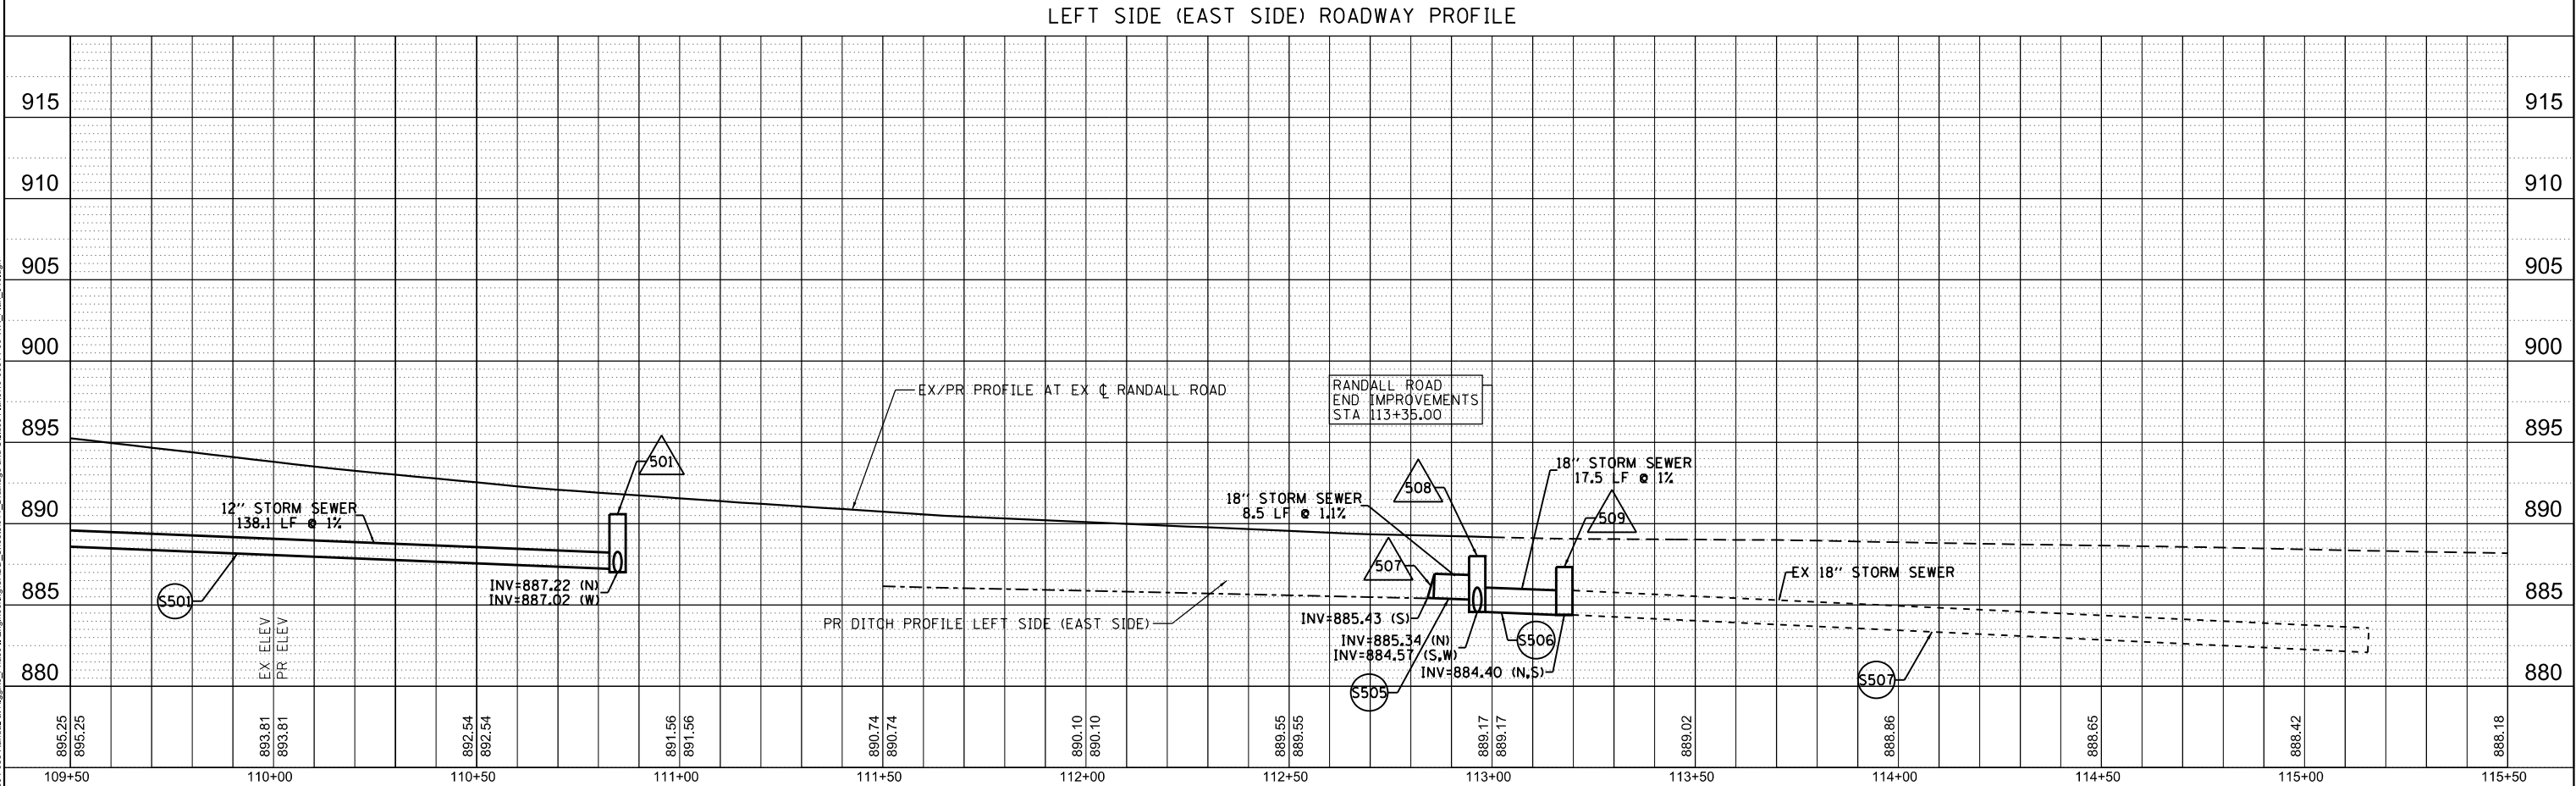

MODEL: Default
FILE NAME: W:\894-088 Randall at Higgins Phase II Engineering\CADD Sheets\011 Drainage and Utilities Plans\19c00514-00-WR Plan_011.dgn



BLA, Inc.


USER NAME = cesario	DESIGNED - TN	REVISED -
PLOT SCALE = 48.0000' / in.	DRAWN - TN	REVISED -
PLOT DATE = 6/19/2025	CHECKED - GJE	REVISED -
	DATE - 02/15/2025	REVISED -

STATE OF ILLINOIS
DEPARTMENT OF TRANSPORTATION

RANDALL ROAD AT IL ROUTE 72 (HIGGINS ROAD)
DRAINAGE AND UTILITY PLAN AND PROFILE

SCALE: 1"=20' SHEET 12 OF 19 SHEETS STA. 187+00.00 TO STA. 193+00.00

F.A.P. RTE.	SECTION	COUNTY	TOTAL SHEETS	SHEET NO.
0336	19-00514-00-WR	KANE	304	112
CONTRACT NO. 61L28				
ILLINOIS FED. AID PROJECT				

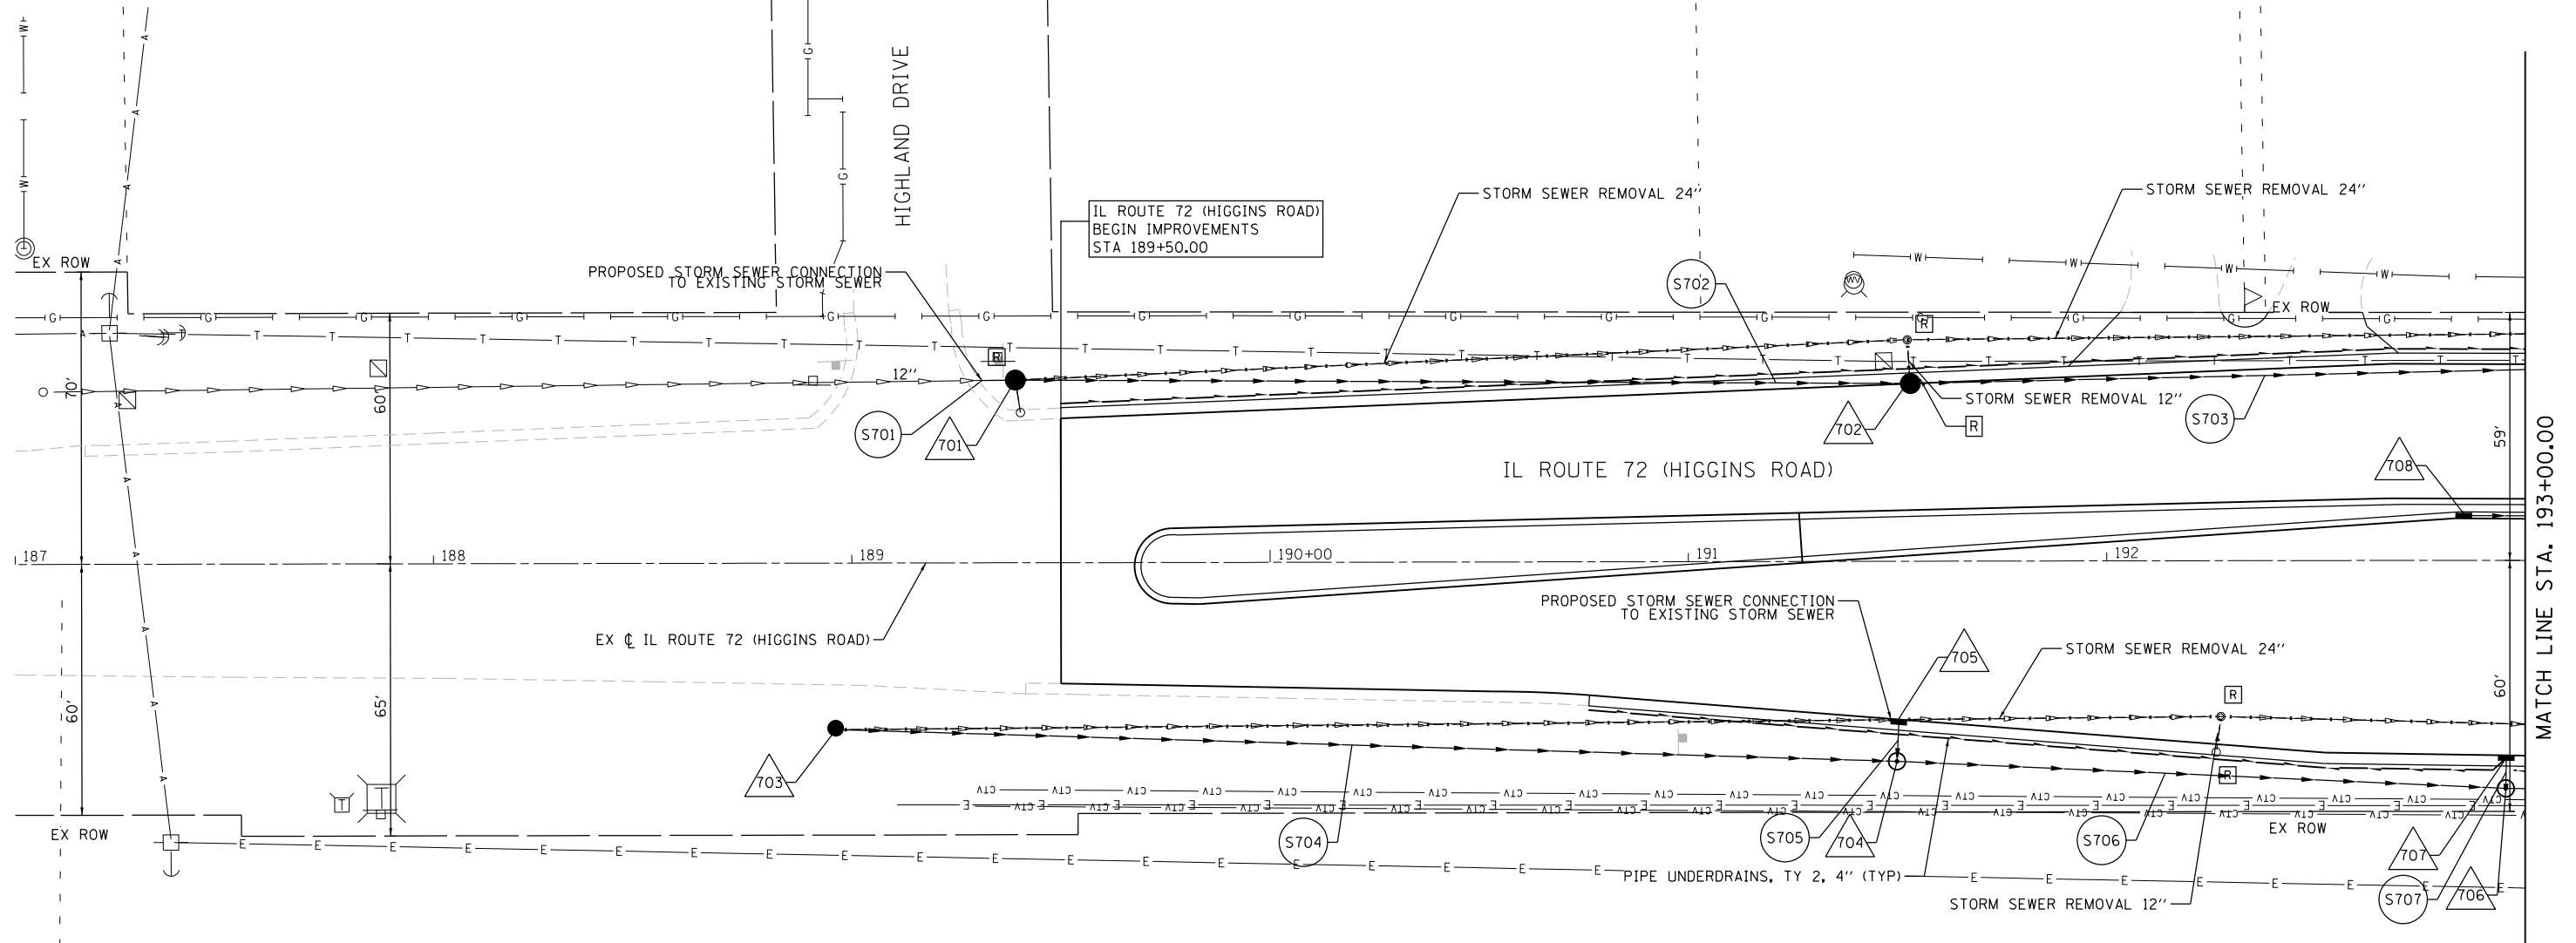

NOTE:


STORM WATER STRUCTURE OFFSET LOCATIONS GIVEN ON THE DETAILED PLANS ARE TO THE FOLLOWING POINTS: A) FOR STRUCTURES FALLING IN THE CURB LINE - TO THE EDGE OF PAVEMENT; B) FOR ALL OTHER STRUCTURE LOCATIONS - TO THE CENTER OF THE STRUCTURE. C) FLARED/CONCRETE END SECTION - END OF SEWER PIPE, BEGINNING OF END SECTION.

LEGEND


△XXX	DRAINAGE STRUCTURE
○SXXX	DRAINAGE PIPE
[R]	STRUCTURE/PIPE TO BE REMOVED
[ADJ]	STRUCTURE TO BE ADJUSTED
→	DRAINAGE ARROW



PLAN	SURVEYED PLOTTED	NOTE BOOK NO.	BY	DATE

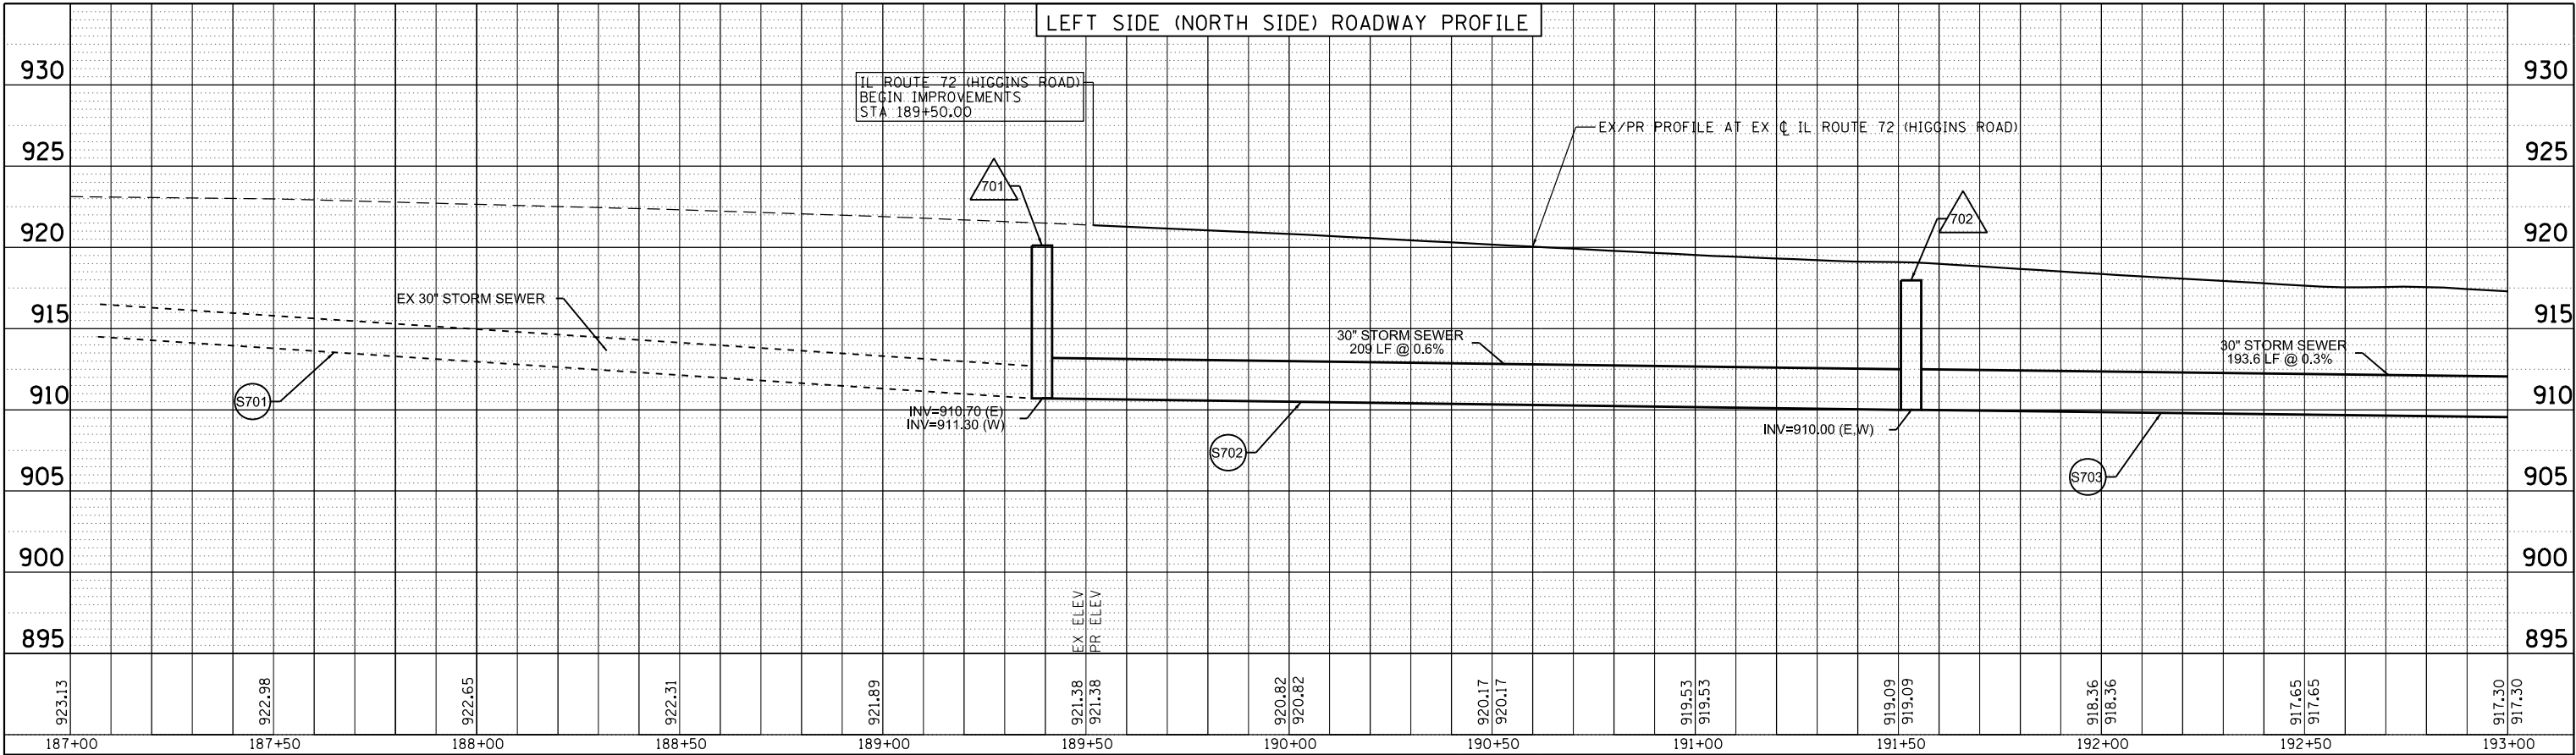

PROFILE	SURVEYED PLOTTED	NOTE BOOK NO.	BY	DATE

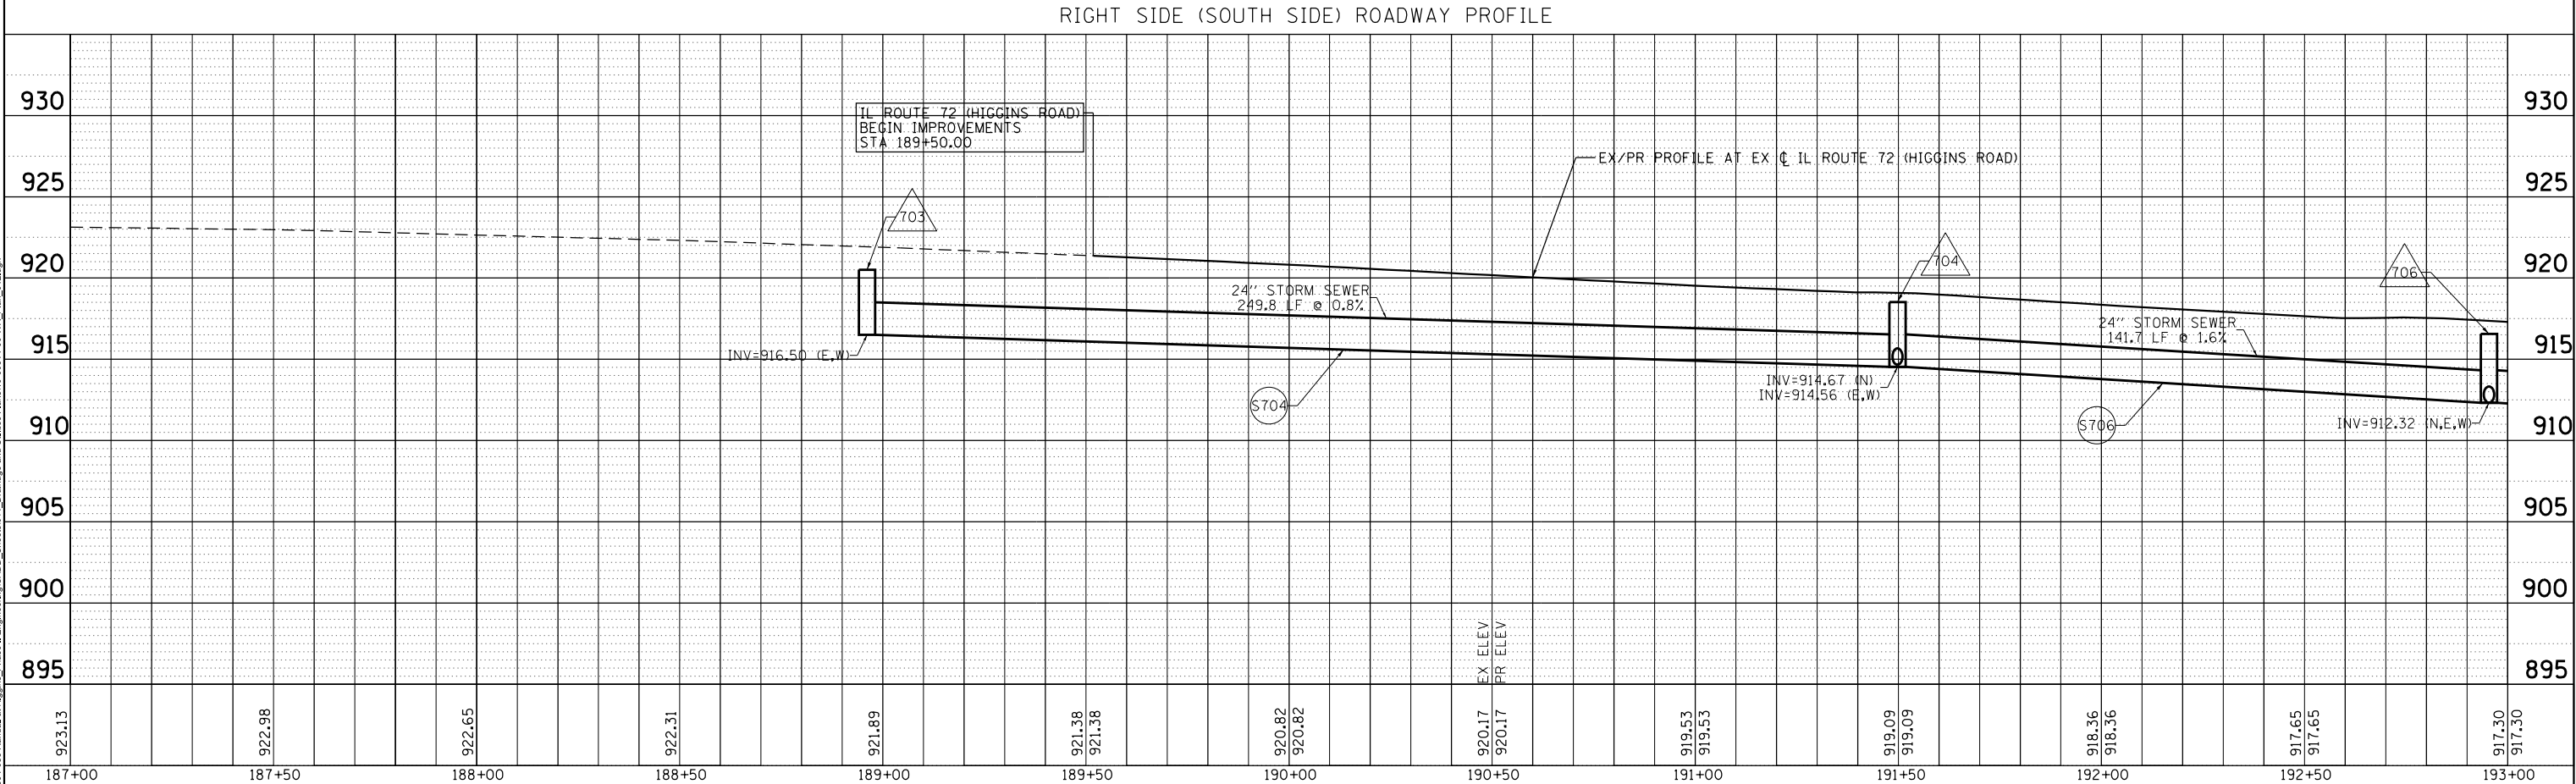

MODEL: Default
FILE NAME: W:\894-088-Randall at Higgins Phase II Engineering\CADD Sheets\011_Drainage and Utilities Plans\15-00514-00-WR_Plan_012.dgn




USER NAME : cesario	DESIGNED - TN	REVISED -
	DRAWN - TN	REVISED -
PLOT SCALE : 40.0000' / in.	CHECKED - GJE	REVISED -
PLOT DATE : 6/19/2025	DATE - 02/15/2025	REVISED -

STATE OF ILLINOIS
DEPARTMENT OF TRANSPORTATION

RANDALL ROAD AT IL ROUTE 72 (HIGGINS ROAD)
DRAINAGE AND UTILITY PLAN AND PROFILE

SCALE: 1"=20' SHEET 13 OF 19 SHEETS STA. 187+00.00 TO STA. 193+00.00

F.A.P. RTE.	SECTION	COUNTY	TOTAL SHEETS	SHEET NO.
0336	19-00514-00-WR	KANE	304	113
CONTRACT NO. 61L28				
ILLINOIS FED. AID PROJECT				

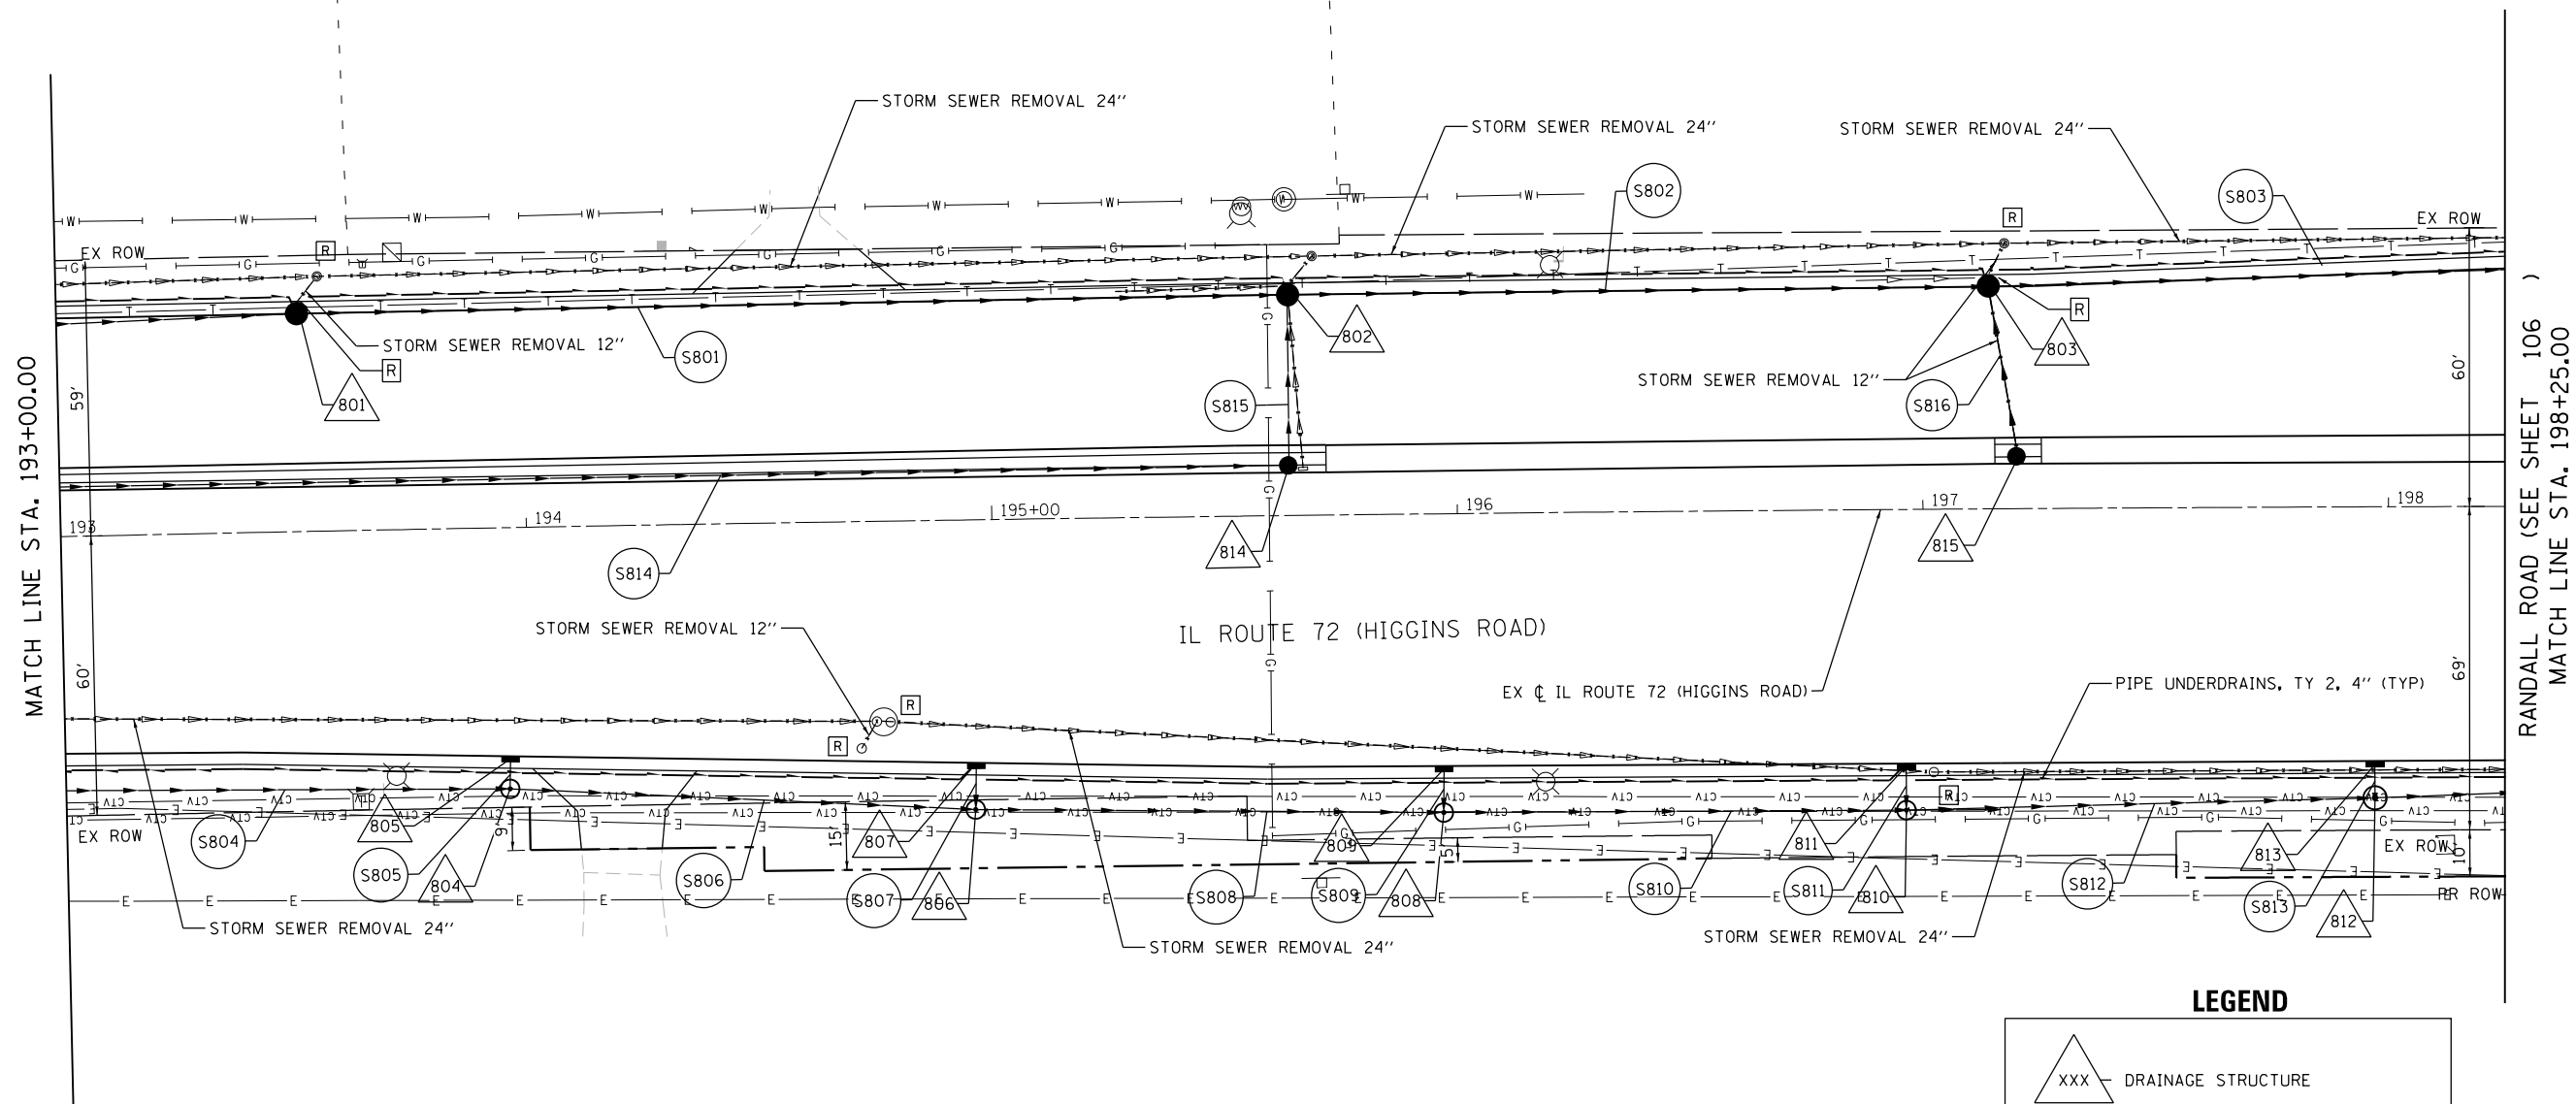

NOTE:
STORM WATER STRUCTURE OFFSET LOCATIONS GIVEN ON THE DETAILED PLANS ARE TO THE FOLLOWING POINTS: A) FOR STRUCTURES FALLING IN THE CURB LINE - TO THE EDGE OF PAVEMENT; B) FOR ALL OTHER STRUCTURE LOCATIONS - TO THE CENTER OF THE STRUCTURE. C) FLARED/CONCRETE END SECTION - END OF SEWER PIPE, BEGINNING OF END SECTION.

LEGEND

- XXX - DRAINAGE STRUCTURE
- SXXX - DRAINAGE PIPE
- [R] - STRUCTURE/PIPE TO BE REMOVED
- [ADJ] - STRUCTURE TO BE ADJUSTED
- ~ - DRAINAGE ARROW

0 20 40 60
SCALE IN FEET

MODEL: Default
FILE NAME: W:\894-088 Randall at Higgins Phase II Engineering\CADD Sheets\011 Drainage and Utilities Plans\180514-00-WR Plan_013.dgn



USER NAME = cesario	DESIGNED - TN	REVISED -
	DRAWN - TN	REVISED -
PLOT SCALE = 48.0011' / in.	CHECKED - GJE	REVISED -
PLOT DATE = 6/19/2025	DATE - 02/15/2025	REVISED -


**STATE OF ILLINOIS
DEPARTMENT OF TRANSPORTATION**

**RANDALL ROAD AT IL ROUTE 72 (HIGGINS ROAD)
DRAINAGE AND UTILITY PLAN AND PROFILE**


SCALE: 1"=20' SHEET 14 OF 19 SHEETS STA. 193+00.00 TO STA. 198+50.00

F.A.P. RTE. 0336	SECTION 19-00514-00-WR	COUNTY KANE	TOTAL SHEETS 304	SHEET NO. 114
CONTRACT NO. 61L28				
ILLINOIS FED. AID PROJECT				

PLAN	SURVEYED PLOTTED	CHECKED ALIGNMENT	CHECKED CADD FILE NAME	BY	DATE
NOTE BOOK NO.					

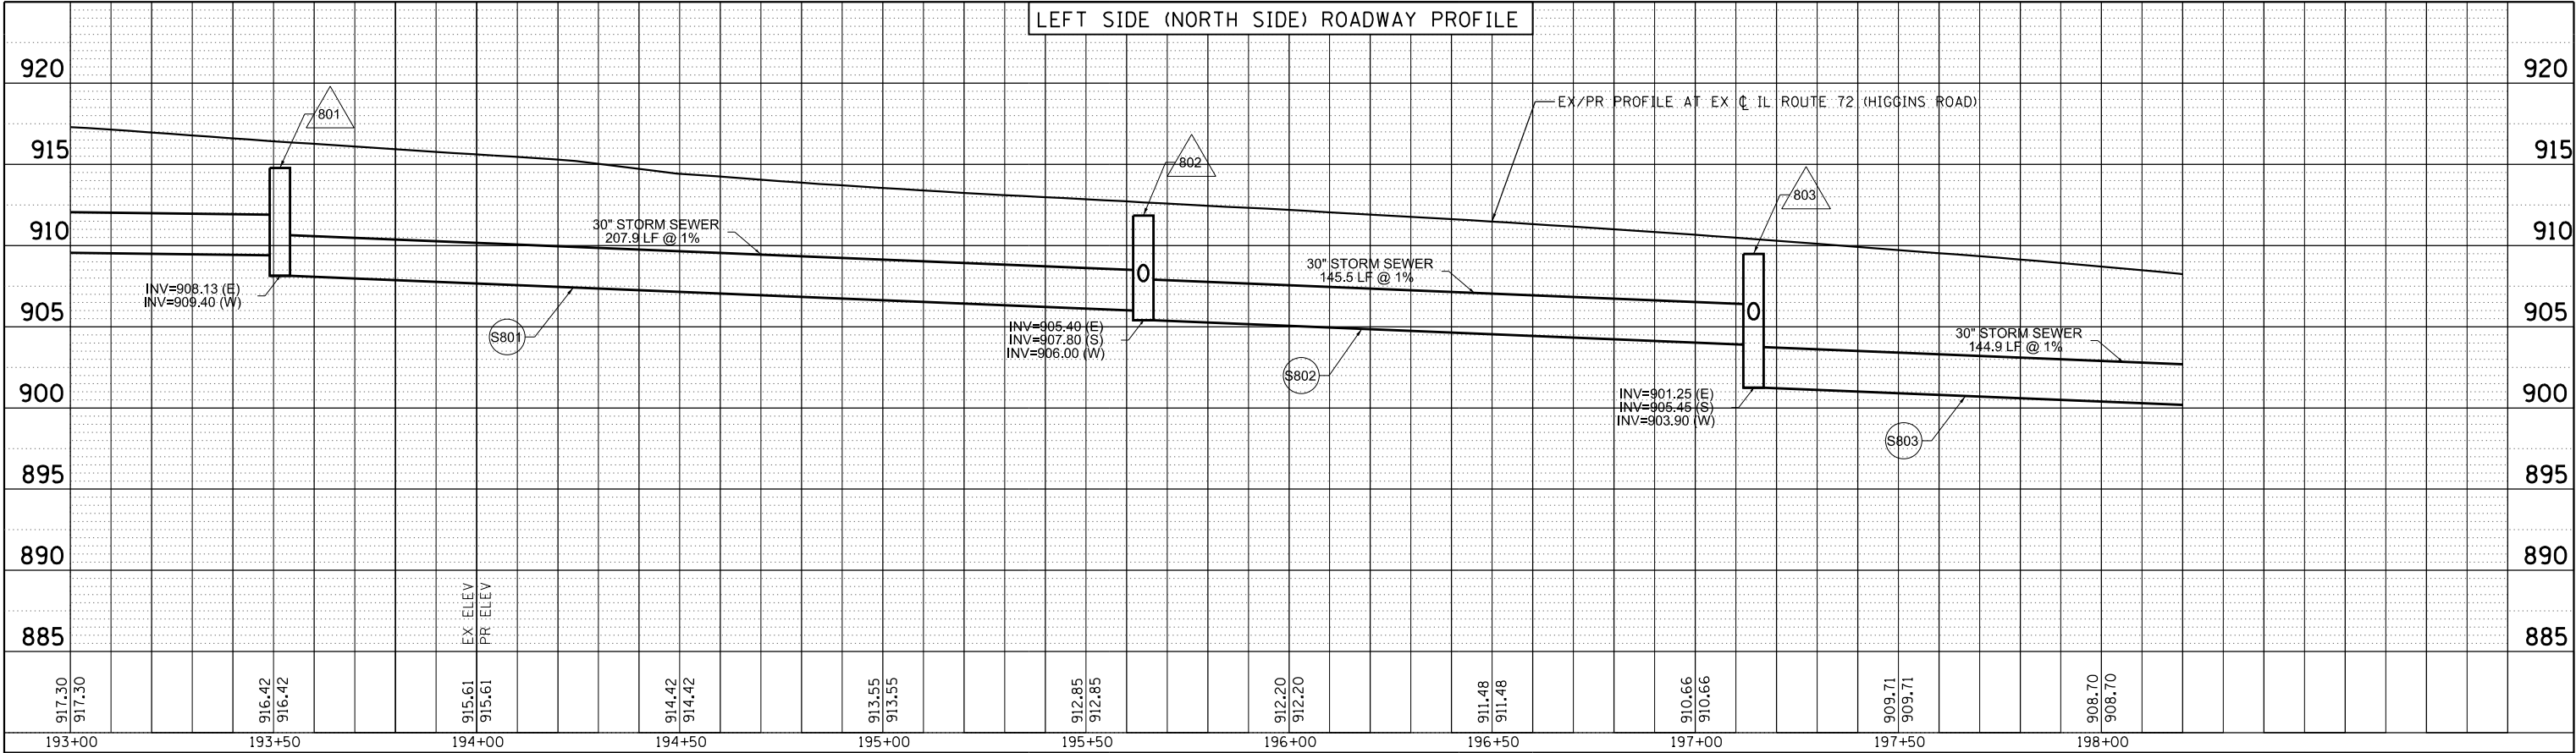

PROFILE	SURVEYED PLOTTED	CHECKED GRADES	CHECKED STRUCTURE	BY	DATE
NOTE BOOK NO.					

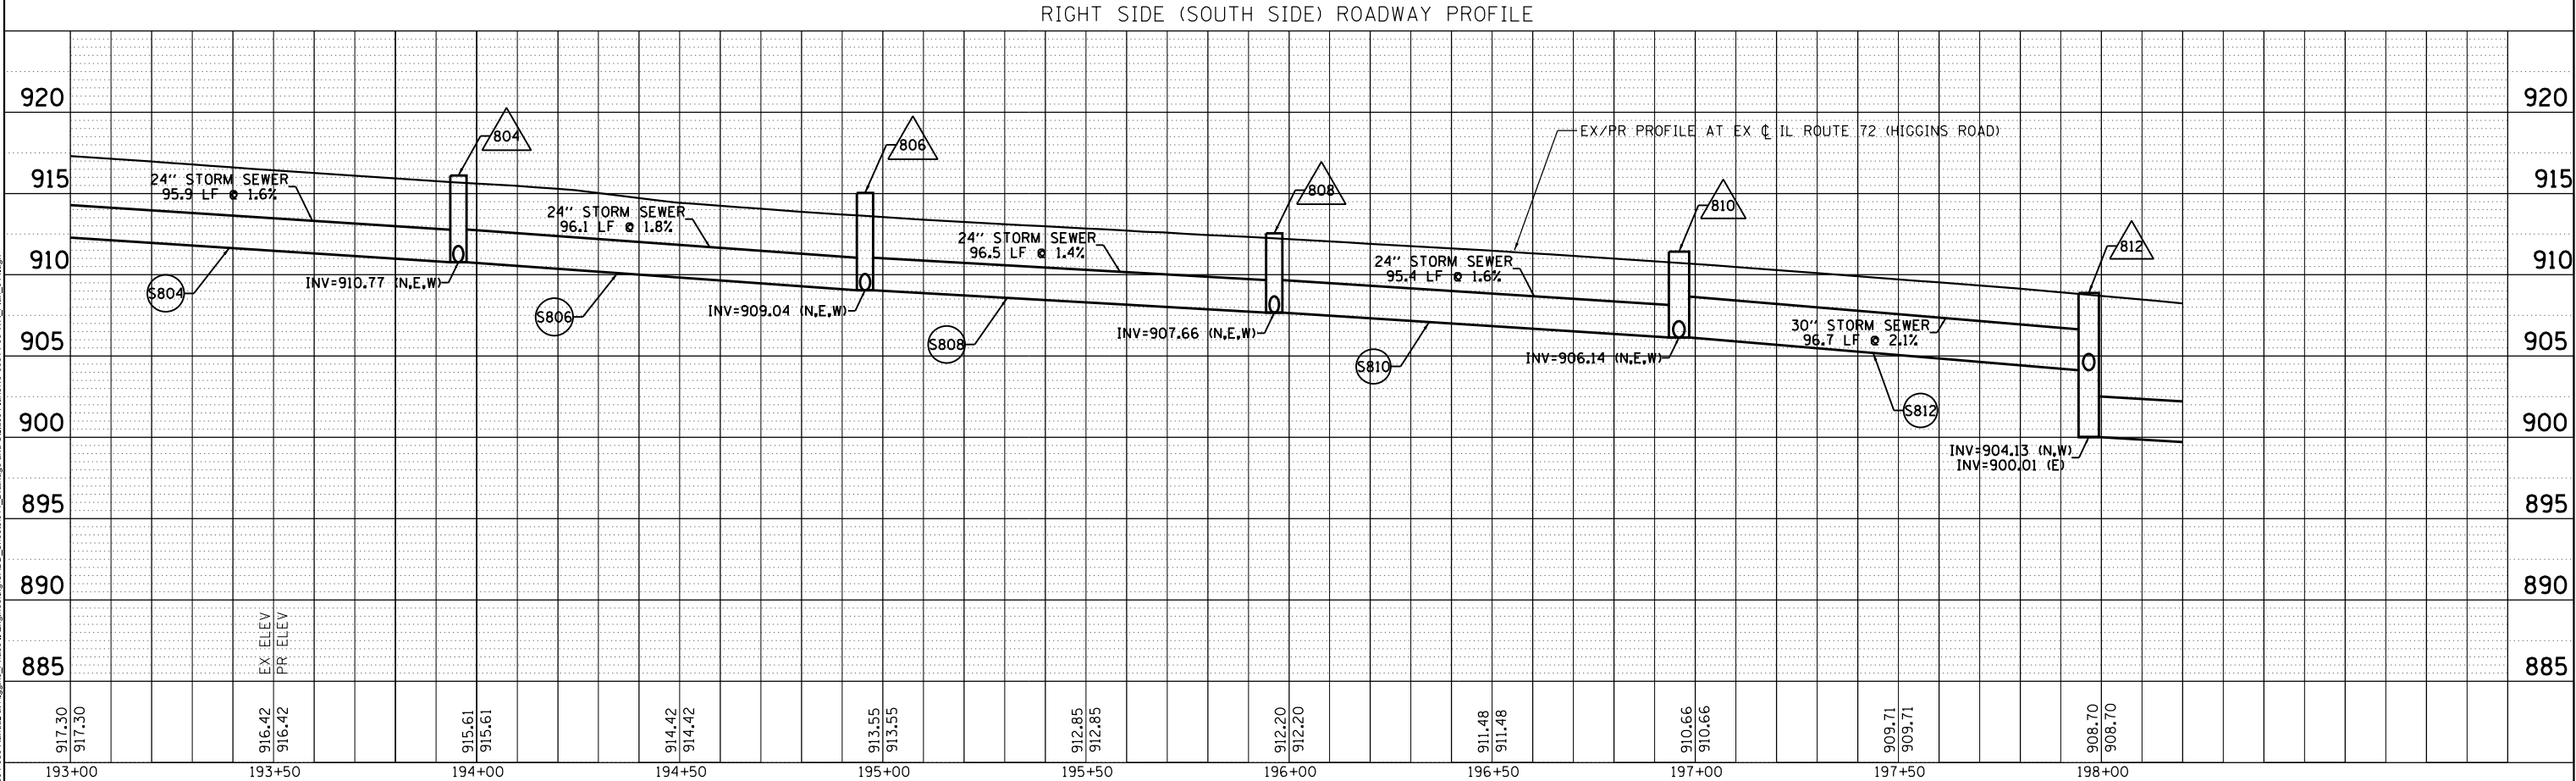

**BLA, Inc.**


USER NAME : cesario	DESIGNED - TN	REVISED -
	DRAWN - TN	REVISED -
PLOT SCALE : 40.0000' / in.	CHECKED - GJE	REVISED -
PLOT DATE : 6/19/2025	DATE - 02/15/2025	REVISED -

STATE OF ILLINOIS
DEPARTMENT OF TRANSPORTATION

RANDALL ROAD AT IL ROUTE 72 (HIGGINS ROAD)
DRAINAGE AND UTILITY PLAN AND PROFILE

SCALE: 1"=20' SHEET 15 OF 19 SHEETS STA. 193+00.00 TO STA. 199+00.00

F.A.P. RTE.	SECTION	COUNTY	TOTAL SHEETS	SHEET NO.
0336	19-00514-00-WR	KANE	304	115
CONTRACT NO. 61L28				
ILLINOIS FED. AID PROJECT				

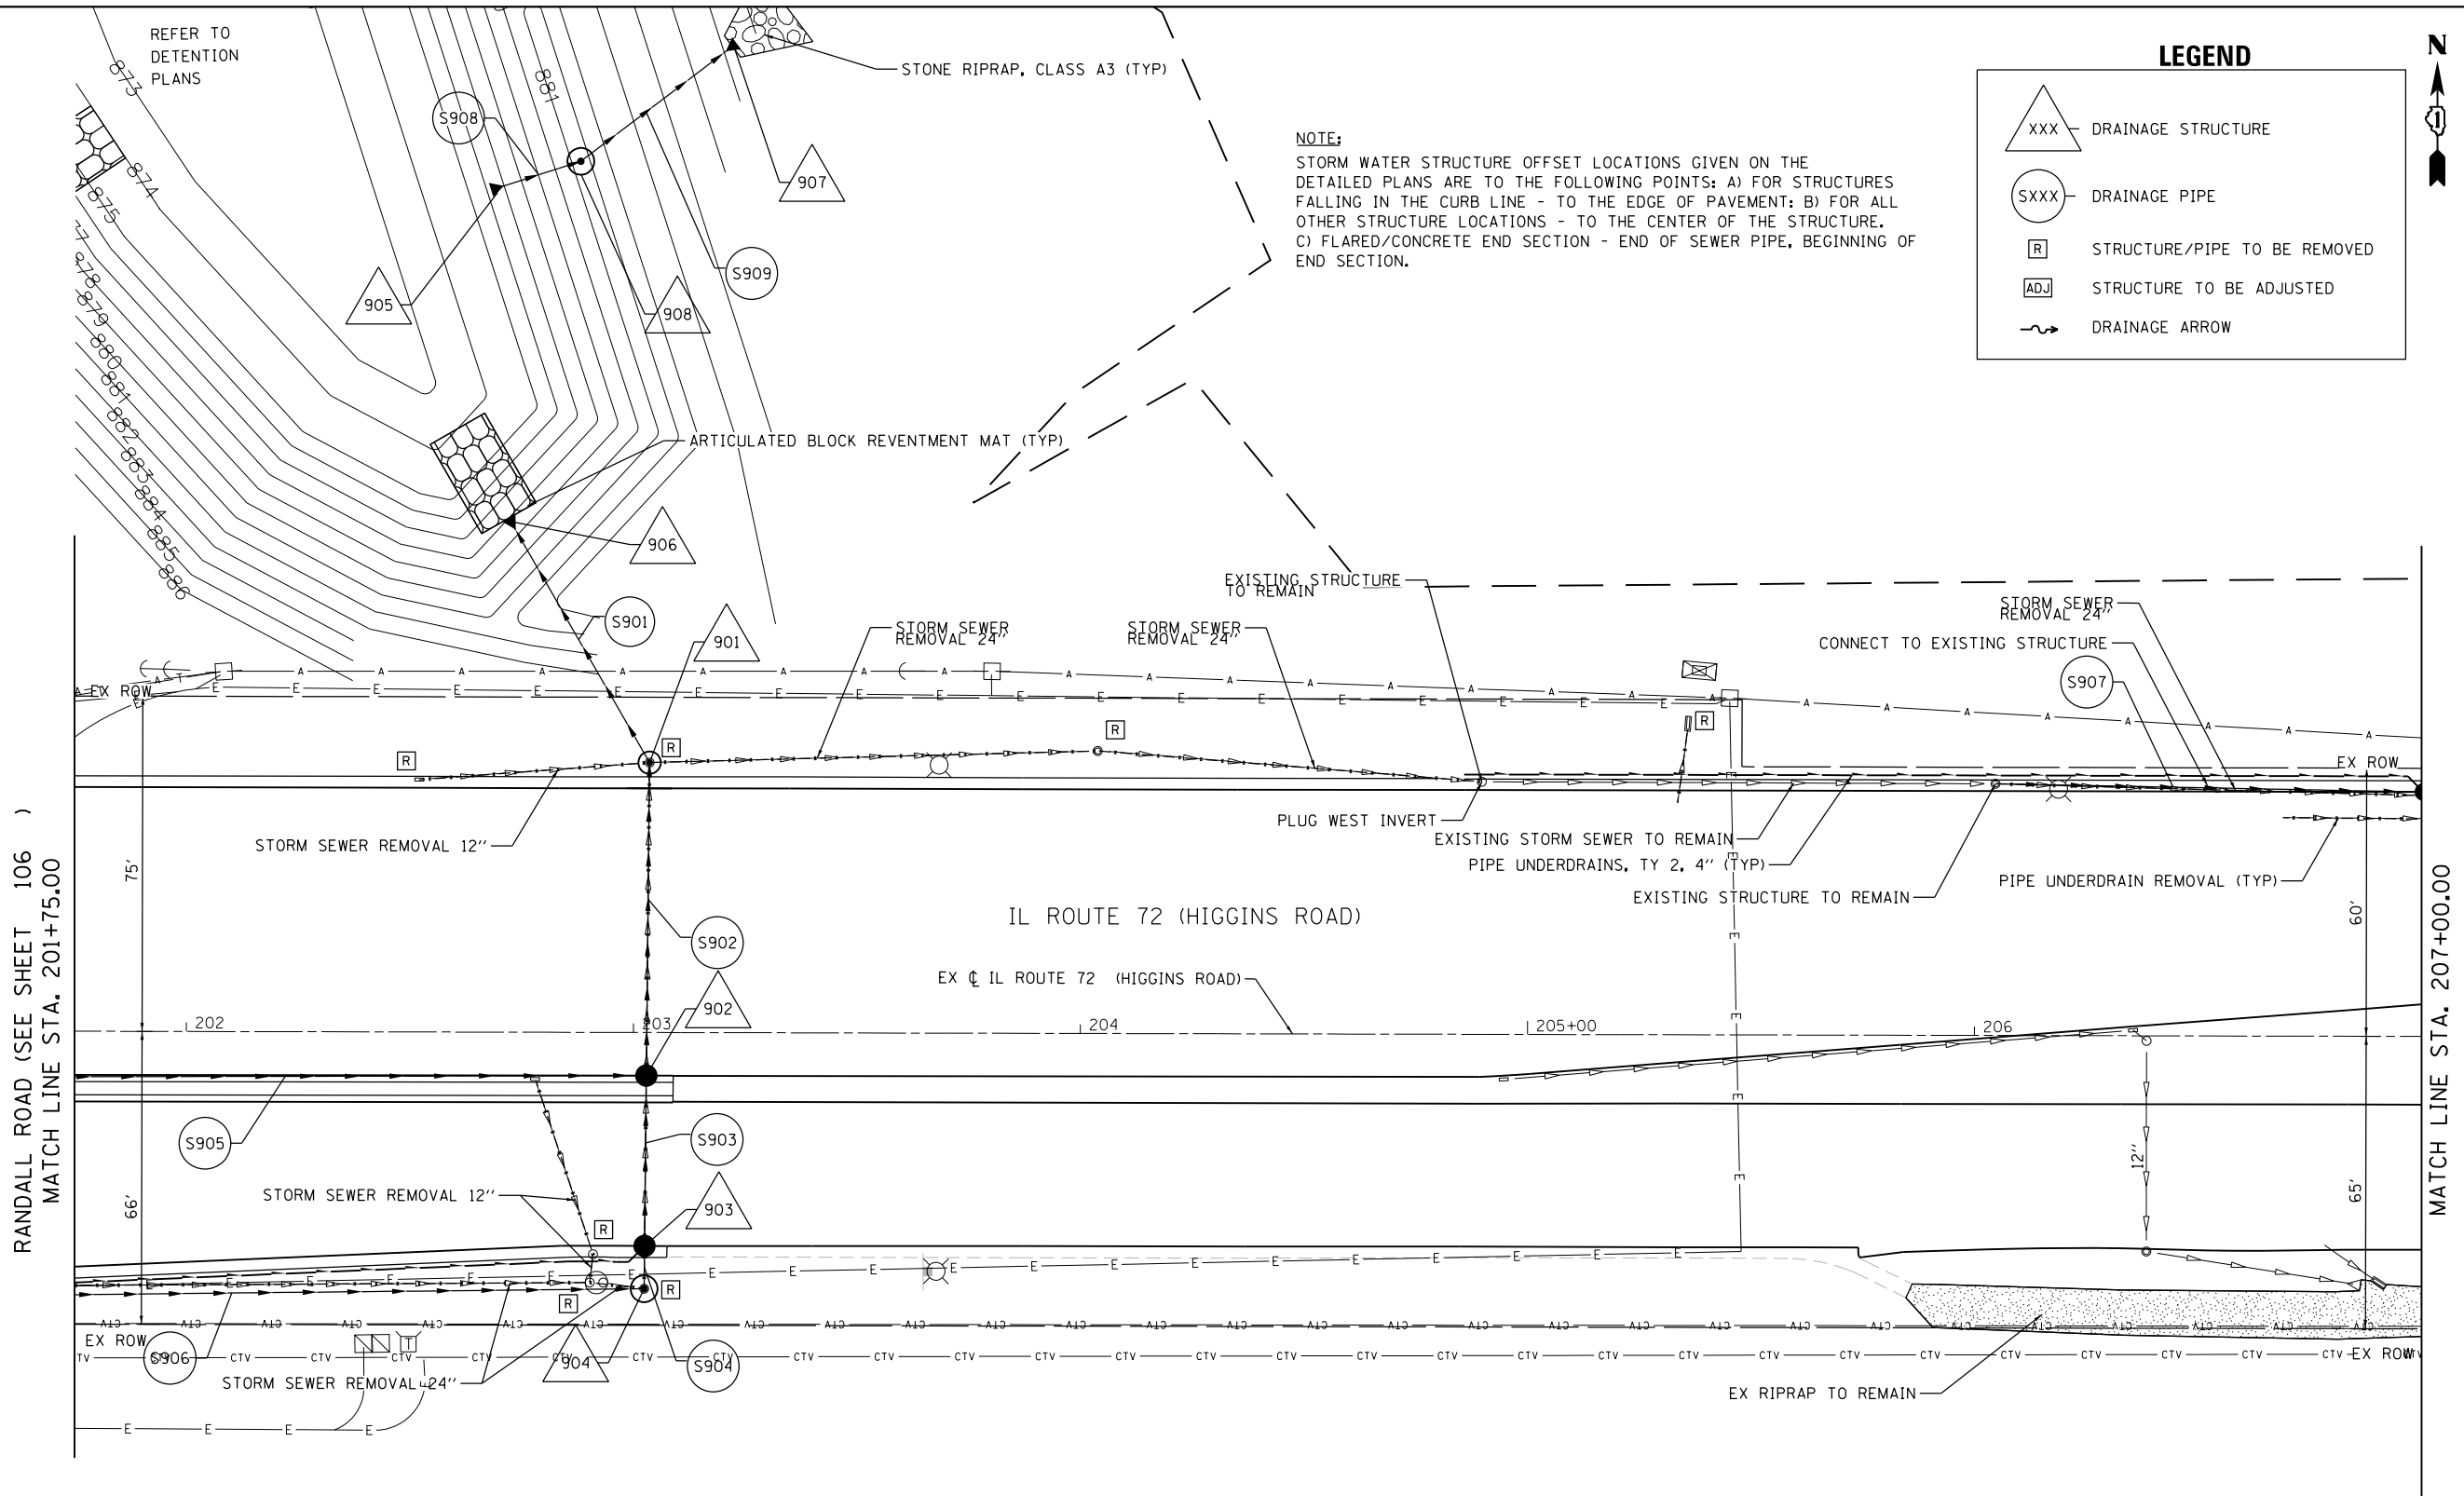

NOTE:
STORM WATER STRUCTURE OFFSET LOCATIONS GIVEN ON THE DETAILED PLANS ARE TO THE FOLLOWING POINTS: A) FOR STRUCTURES FALLING IN THE CURB LINE - TO THE EDGE OF PAVEMENT; B) FOR ALL OTHER STRUCTURE LOCATIONS - TO THE CENTER OF THE STRUCTURE. C) FLARED/CONCRETE END SECTION - END OF SEWER PIPE, BEGINNING OF END SECTION.

LEGEND

 
DRAINAGE STRUCTURE

DRAINAGE PIPE

STRUCTURE/PIPE TO BE REMOVED

STRUCTURE TO BE ADJUSTED

DRAINAGE ARROW



MODEL: Default
FILE NAME: W:\894-088 Randall at Higgins Phase II Engineering\CADD Sheets\011 Drainage and Utilities Plans\19-00514-00-WR Plan_015.dgn

BLA, Inc.

USER NAME = cesario	DESIGNED - TN	REVISED -
PLOT SCALE = 48.0004' / in.	DRAWN - TN	REVISED -
PLOT DATE = 6/19/2025	CHECKED - GJE	REVISED -
	DATE - 02/15/2025	REVISED -

**STATE OF ILLINOIS
DEPARTMENT OF TRANSPORTATION**

RANDALL ROAD AT IL ROUTE 72 (HIGGINS ROAD)
DRAINAGE AND UTILITY PLAN AND PROFILE



SCALE: 1"=20' SHEET 16 OF 19 SHEETS STA. 95+50.00 TO STA. 101+50.00

F.A.P. RTE. 0336	SECTION 19-00514-00-WR	COUNTY KANE	TOTAL SHEETS 304	SHEET NO. 116
CONTRACT NO. 61L28				
ILLINOIS FED. AID PROJECT				

PLAN	SURVEYED	BY	DATE
	PLOTTED		
NOTE BOOK NO.	CHECKED		
	FILE NAME		

PROFILE	SURVEYED	BY	DATE
	PLOTTED		
NOTE BOOK NO.	GRADES CHECKED		
	STRUCTURE NOTATIONS CHKD		

MODEL: Default
FILE NAME: W:\894988.Randall at Higgins Phase II Engineering\CADD Sheets\011_Drainage and Utilities Plans\15-00514-00-WR_Plan_015.dgn

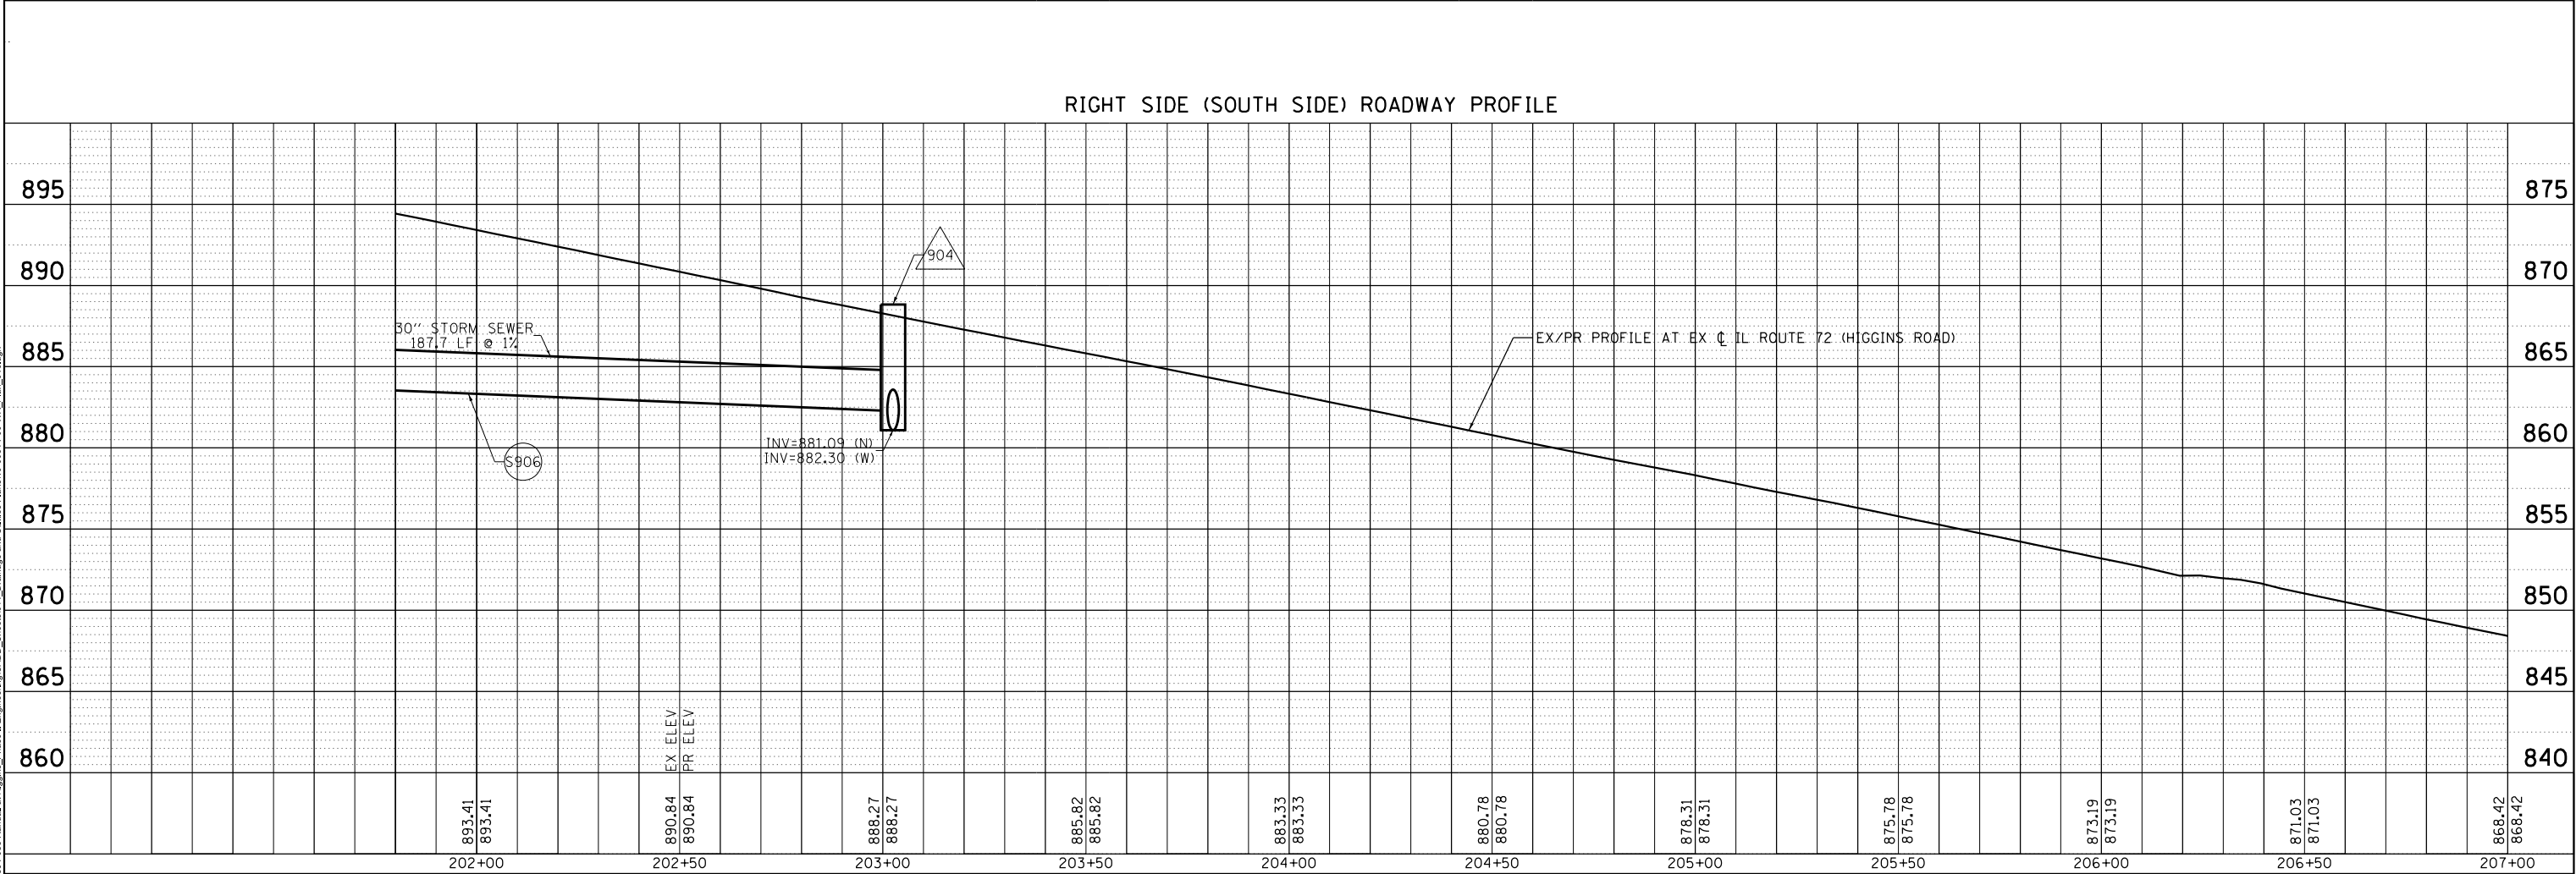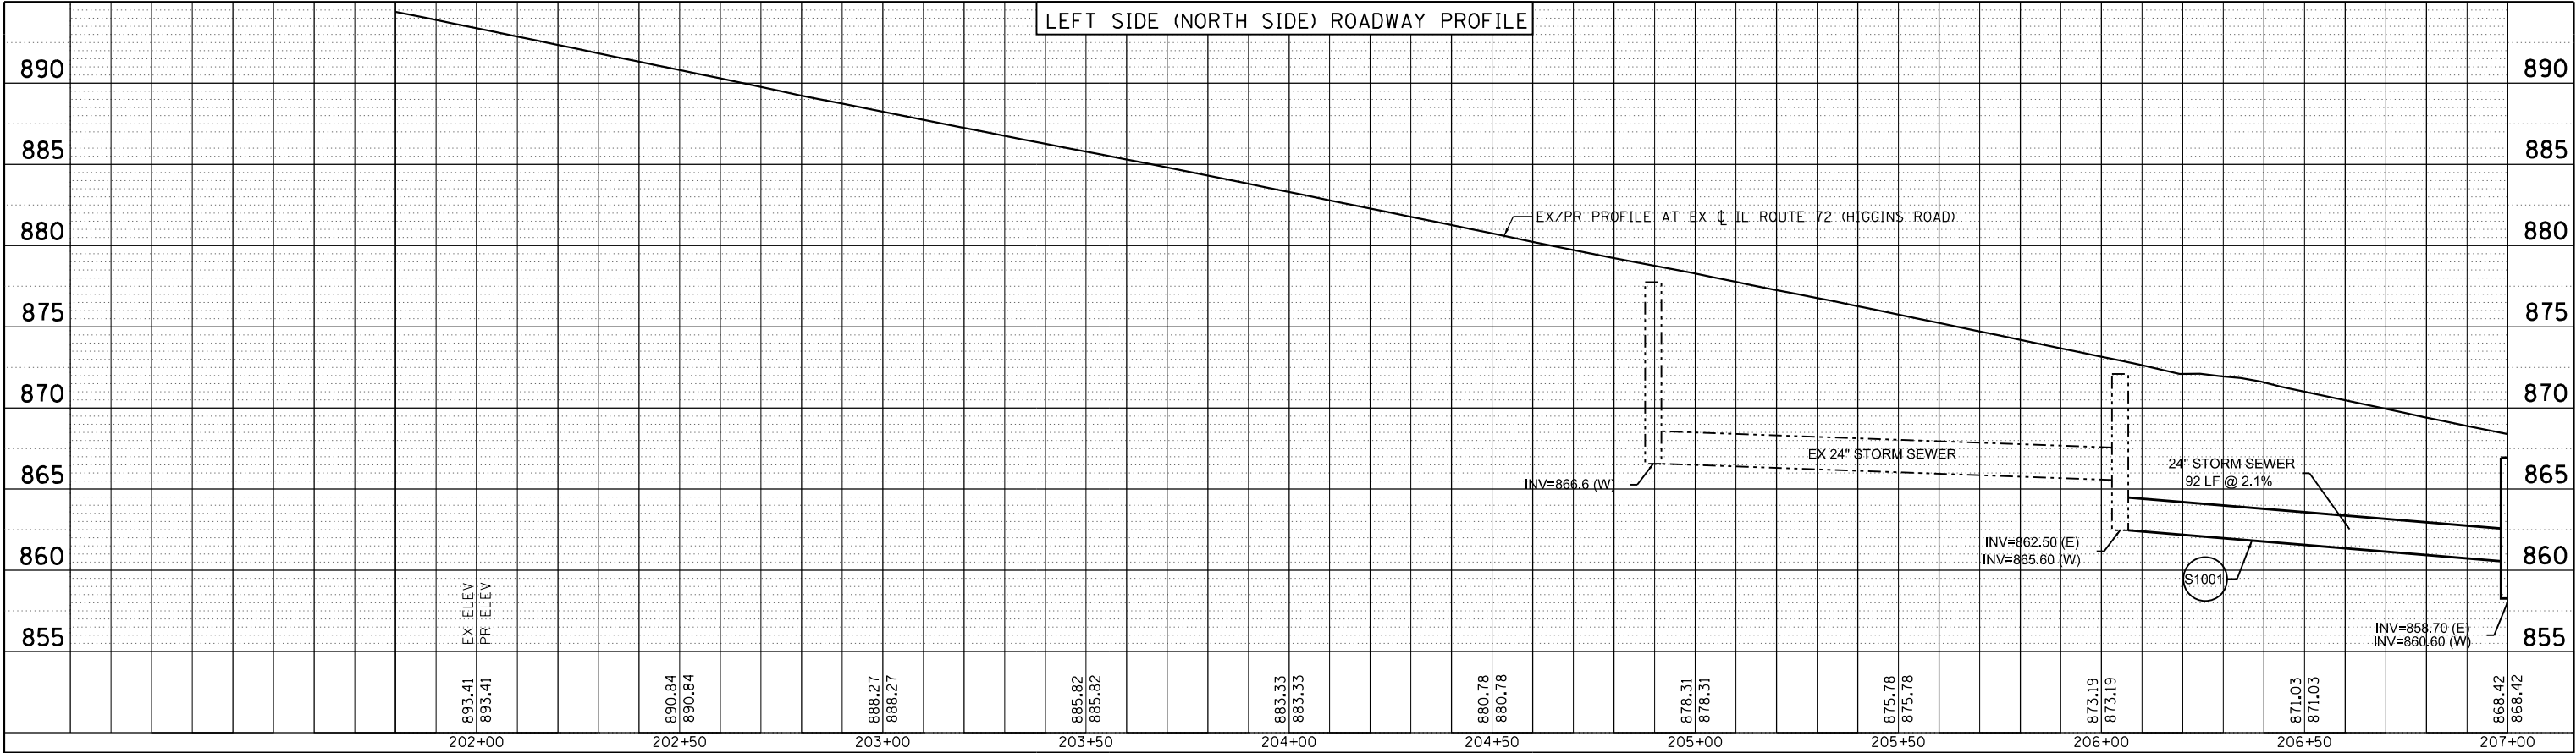


USER NAME : cesario	DESIGNED - TN	REVISED -
	DRAWN - TN	REVISED -
PLOT SCALE : 40.0000' / in.	CHECKED - GJE	REVISED -
PLOT DATE : 6/19/2025	DATE - 02/15/2025	REVISED -

STATE OF ILLINOIS
DEPARTMENT OF TRANSPORTATION

RANDALL ROAD AT IL ROUTE 72 (HIGGINS ROAD)
DRAINAGE AND UTILITY PLAN AND PROFILE

SCALE: 1"=20' SHEET 17 OF 19 SHEETS STA. 201+00.00 TO STA. 207+00.00

F.A.P. RTE.	SECTION	COUNTY	TOTAL SHEETS	SHEET NO.
0336	19-00514-00-WR	KANE	304	117
CONTRACT NO. 61L28				
ILLINOIS FED. AID PROJECT				

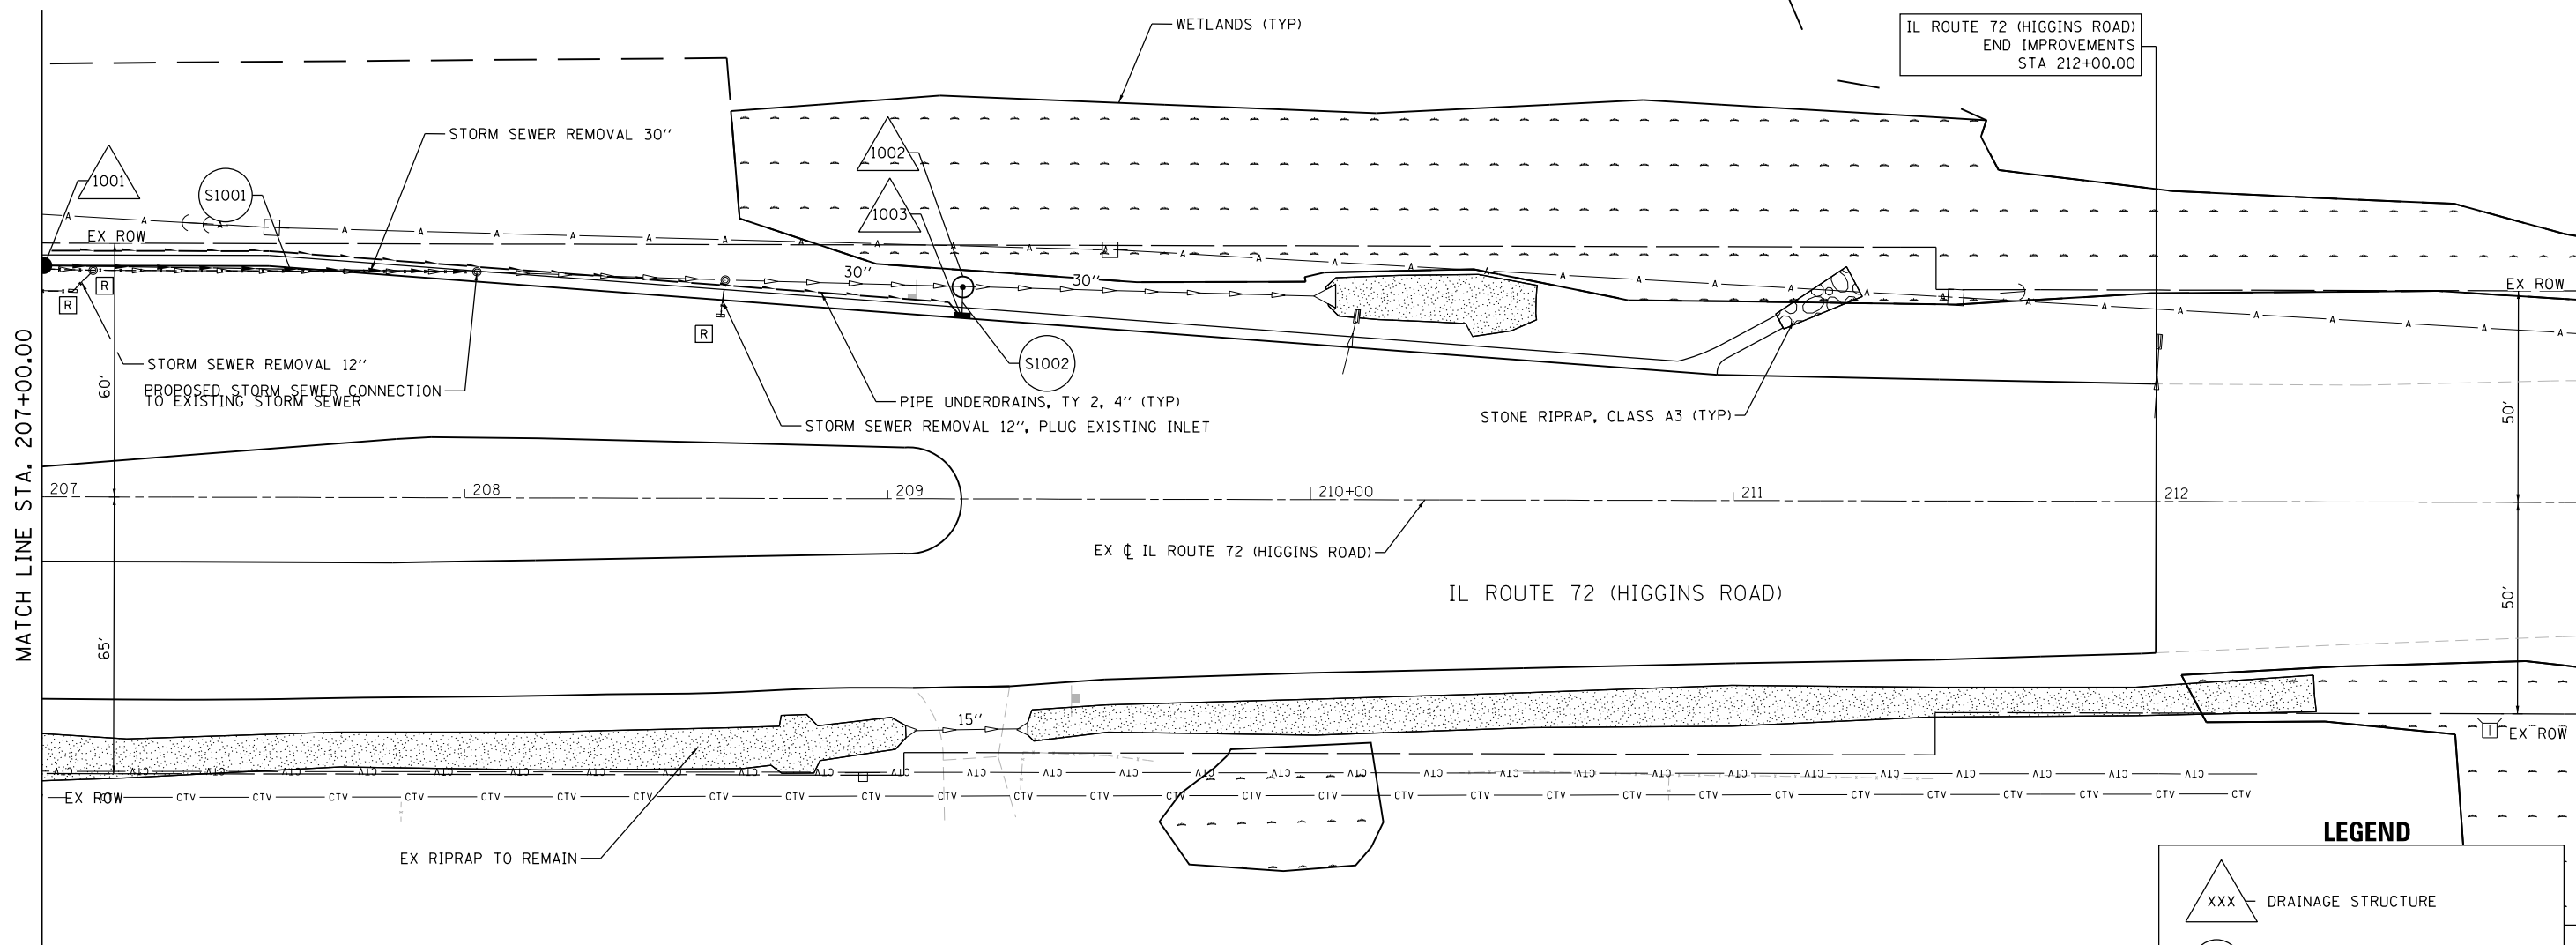

LEGEND

- △XXX DRAINAGE STRUCTURE
- SXXX DRAINAGE PIPE
- [R] STRUCTURE/PIPE TO BE REMOVED
- [ADJ] STRUCTURE TO BE ADJUSTED
- DRAINAGE ARROW

NOTE:

STORM WATER STRUCTURE OFFSET LOCATIONS GIVEN ON THE DETAILED PLANS ARE TO THE FOLLOWING POINTS: A) FOR STRUCTURES FALLING IN THE CURB LINE - TO THE EDGE OF PAVEMENT; B) FOR ALL OTHER STRUCTURE LOCATIONS - TO THE CENTER OF THE STRUCTURE. C) FLARED/CONCRETE END SECTION - END OF SEWER PIPE, BEGINNING OF END SECTION.



MODEL: Default
FILE NAME: W:\894-088 Randall at Higgins Phase II Engineering\CADD Sheets\011 Drainage and Utilities Plans\19-00514-00-WR Plan_017.dgn



BLA, Inc.

USER NAME = cesario	DESIGNED - TN	REVISED -
	DRAWN - TN	REVISED -
PLOT SCALE = 48.0004' / in.	CHECKED - GJE	REVISED -
PLOT DATE = 6/19/2025	DATE - 02/15/2025	REVISED -

STATE OF ILLINOIS
DEPARTMENT OF TRANSPORTATION

RANDALL ROAD AT IL ROUTE 72 (HIGGINS ROAD)
DRAINAGE AND UTILITY PLAN AND PROFILE



SCALE: 1"=20' SHEET 18 OF 19 SHEETS STA. 207+00.00 TO STA. 213+00.00

F.A.P. RTE.	SECTION	COUNTY	TOTAL SHEETS	SHEET NO.
0336	19-00514-00-WR	KANE	304	118
CONTRACT NO. 61L28				
ILLINOIS FED. AID PROJECT				

PLAN	SURVEYED PLOTTED	BY	DATE
CHECKED FILED			

PROFILE	SURVEYED PLOTTED	BY	DATE
CHECKED FILED			

MODEL: Default
FILE NAME: W8894-088 Randall at Higgins Phase II Engineering\CADD Sheets\011_Drainage and Utilities Plans\1540514-00-WR_Plan_015.dgn

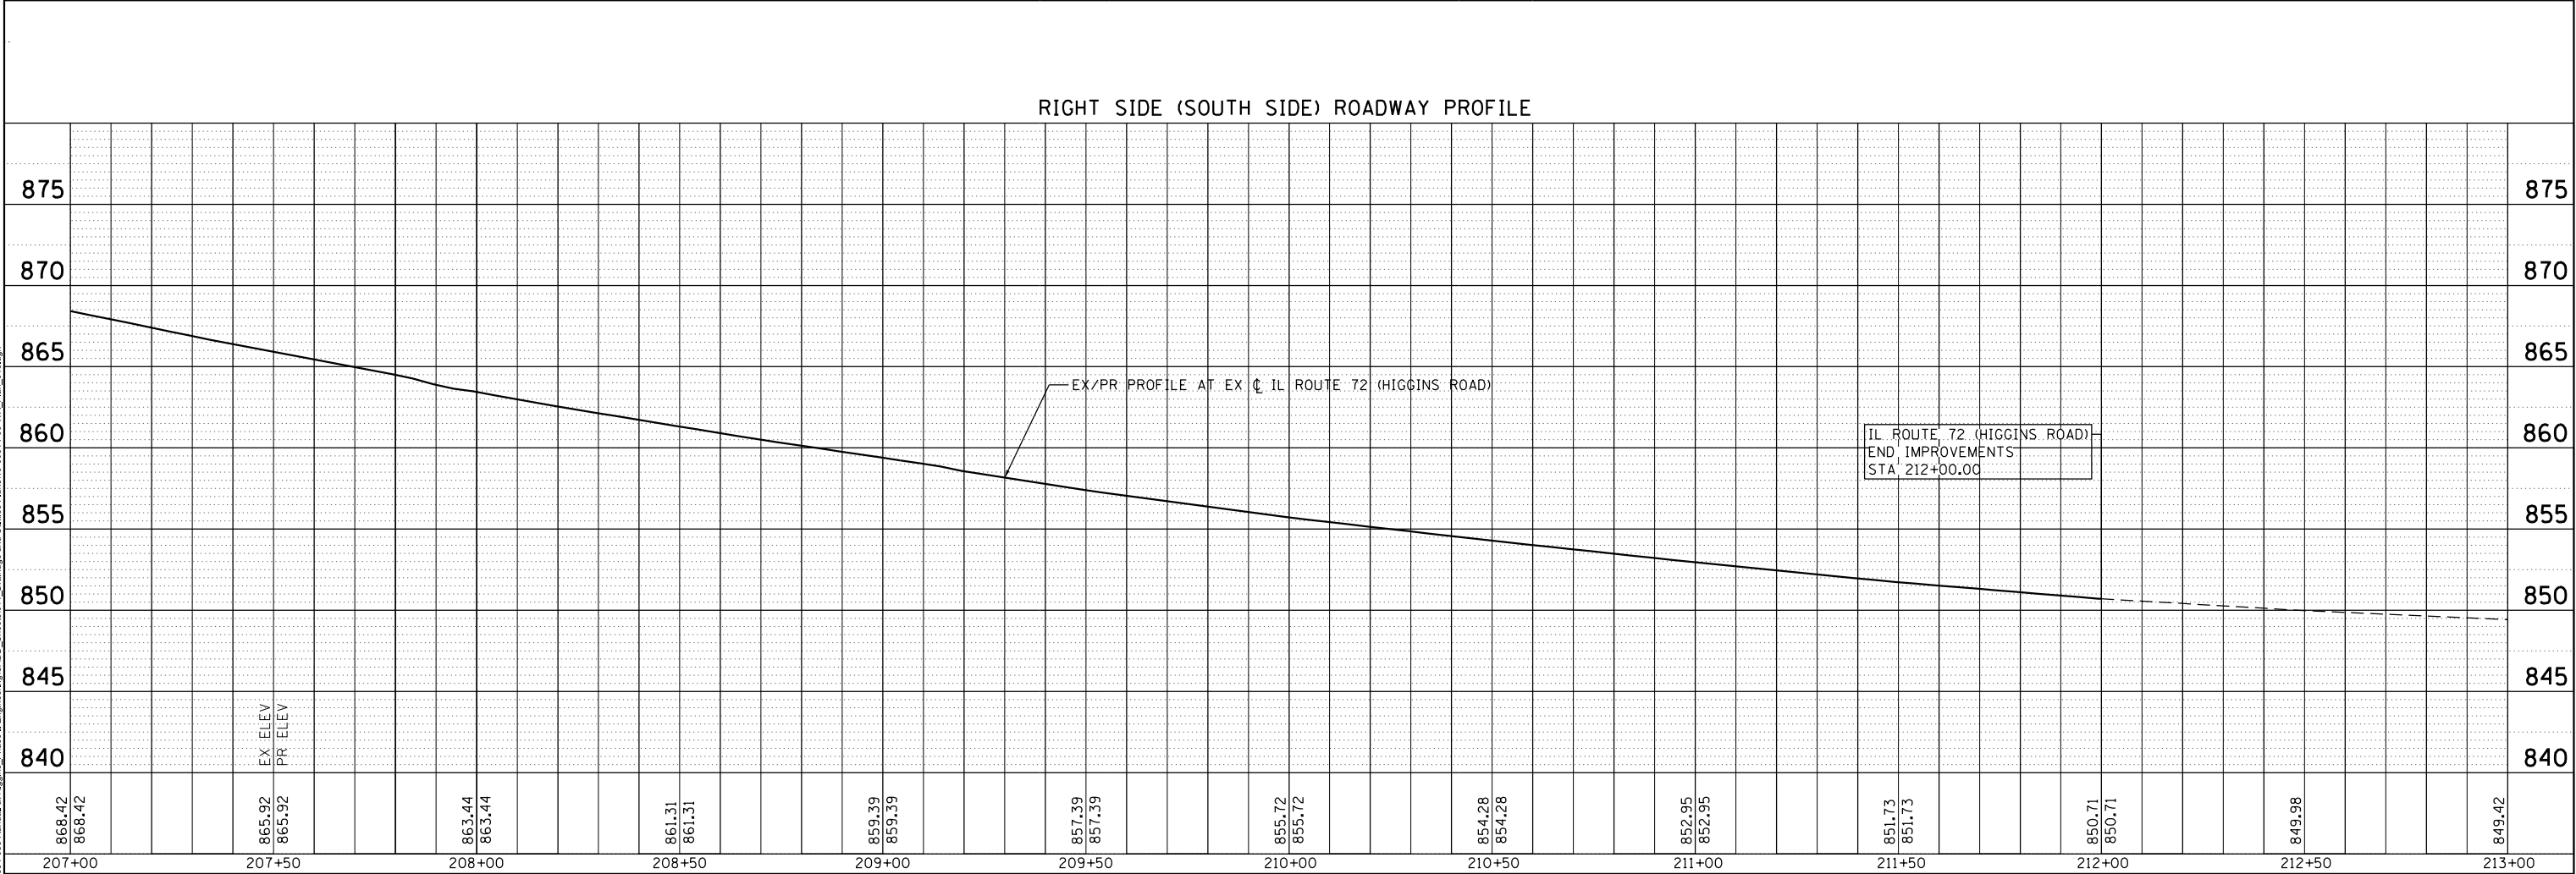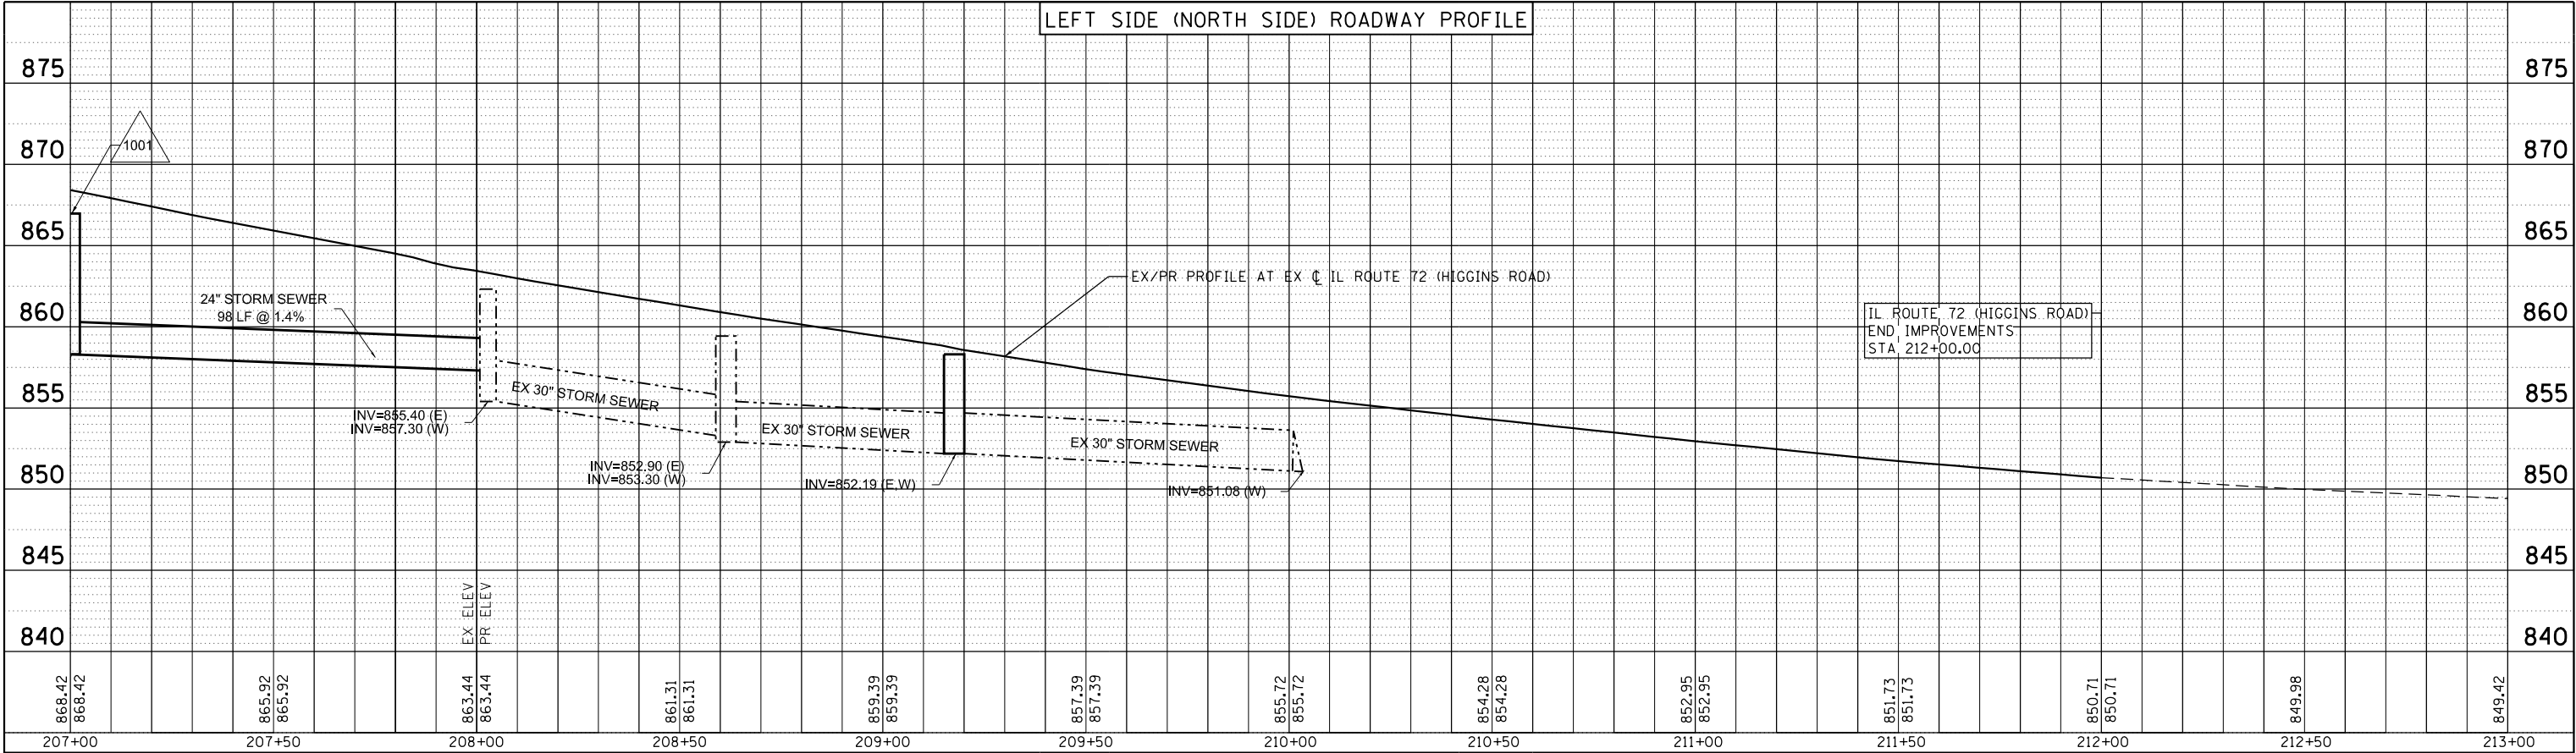

USER NAME : cesario	DESIGNED - TN	REVISED -
	DRAWN - TN	REVISED -
PLOT SCALE : 40.0000' / in.	CHECKED - GJE	REVISED -
PLOT DATE : 6/19/2025	DATE - 02/15/2025	REVISED -

STATE OF ILLINOIS
DEPARTMENT OF TRANSPORTATION

RANDALL ROAD AT IL ROUTE 72 (HIGGINS ROAD)
DRAINAGE AND UTILITY PLAN AND PROFILE

SCALE: 1"=20' SHEET 19 OF 19 SHEETS STA. 207+00.00 TO STA. 213+00.00

F.A.P. RTE.	SECTION	COUNTY	TOTAL SHEETS	SHEET NO.
0336	19-00514-00-WR	KANE	304	119
CONTRACT NO. 61L28				
ILLINOIS FED. AID PROJECT				

MODEL: Default
FILE NAME: W:\004-088 Randall at Higgins Phase II Engineering\CADD Sheets\011 Drainage and Utilities Plans\19-00514-00-VR Plan_Basin_019.dgn



BLA, Inc.


USER NAME = cesario	DESIGNED - TN	REVISED -
PLOT SCALE = 48.0000' / in.	DRAWN - TN	REVISED -
PLOT DATE = 6/19/2025	CHECKED - GJE	REVISED -
	DATE - 02/15/2025	REVISED -

STATE OF ILLINOIS
DEPARTMENT OF TRANSPORTATION

RANDALL ROAD AT IL ROUTE 72 (HIGGINS ROAD)
DETENTION BASIN GRADING PLAN

SCALE: 1"=20' SHEET 1 OF 1 SHEETS STA. NA TO STA. NA

F.A.P. RTE. 0336	SECTION 19-00514-00-WR	COUNTY KANE	TOTAL SHEETS 304	SHEET NO. 120
CONTRACT NO. 61L28				
ILLINOIS FED. AID PROJECT				

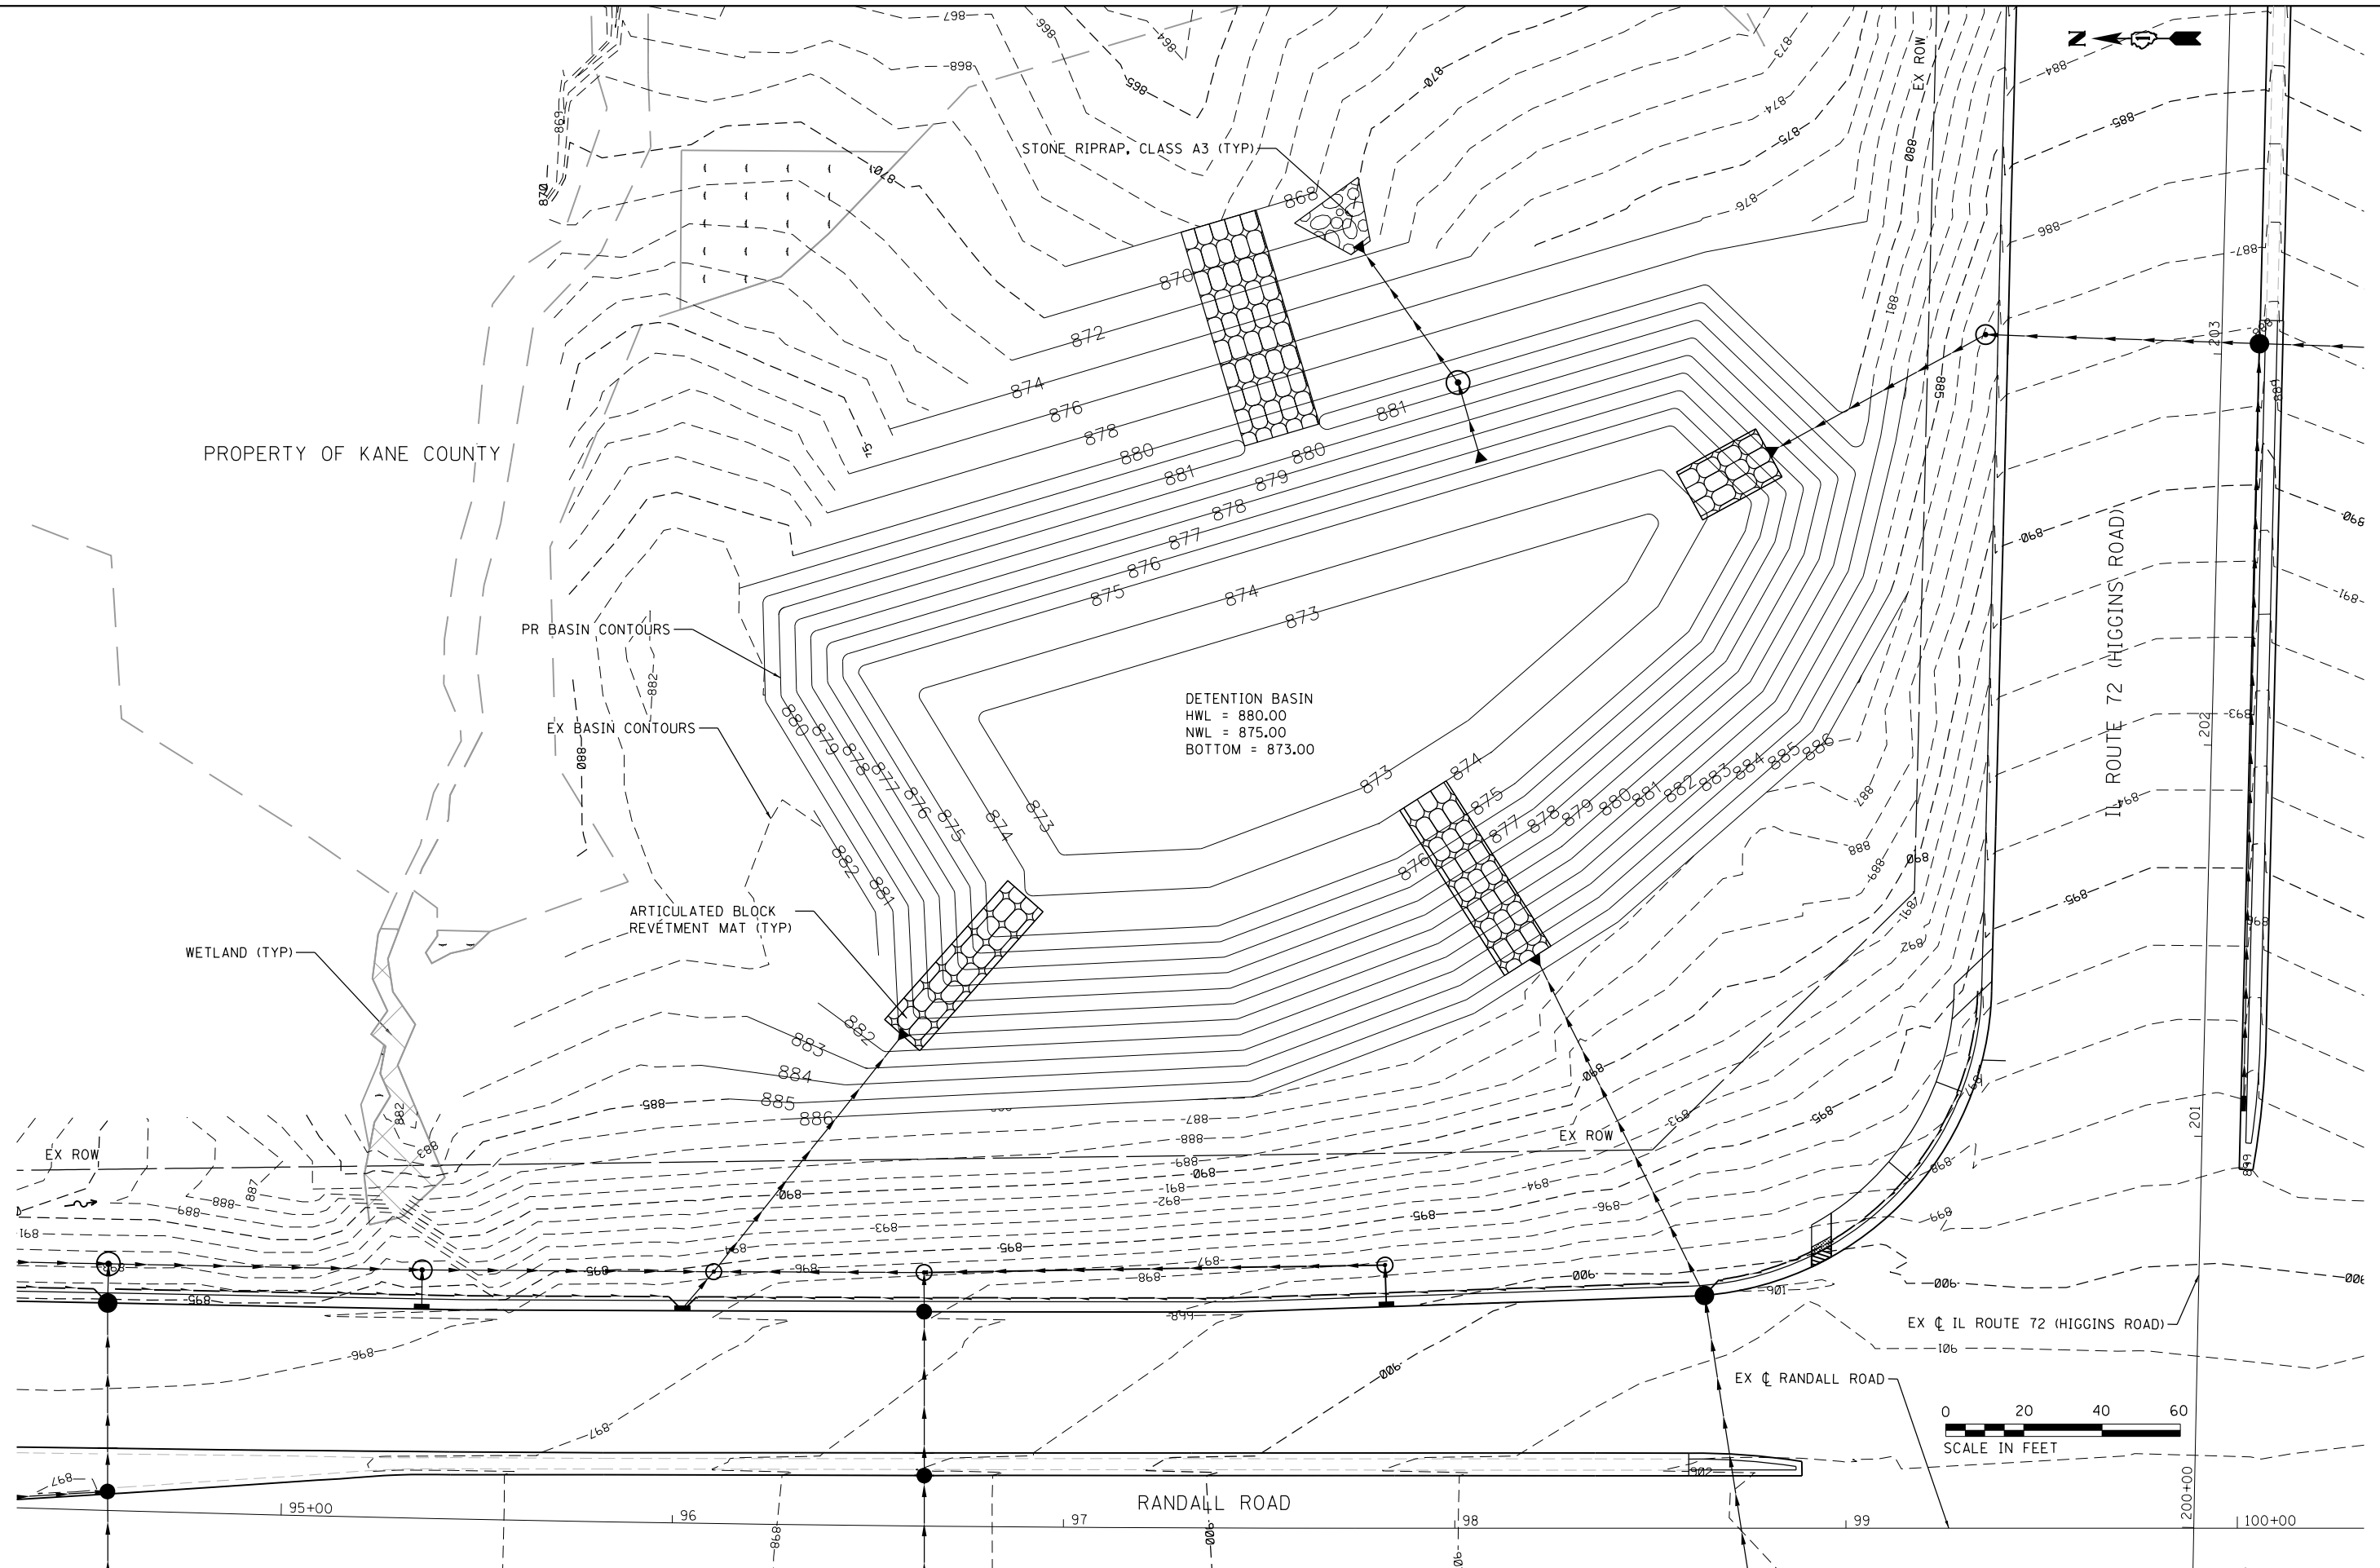

MODEL: Default
FILE NAME: W:\894-088 Randall at Higgins Phase II Engineering\CADD Sheets\011 Drainage and Utilities Plans\1b-00514-00-WR TABLES.dgn

PROPOSED DRAINAGE STRUCTURE TABLE														
SHEET	STRUCT. NO.	ALIGN	STATION	OFFSET (FT)	STRUCTURE TYPE / SIZE				FRAME AND GRATE OR LID	RIM ELEV (FT)	INVERT ELEVATIONS			
					MH	CB	INL	OTHER			NORTH	EAST	SOUTH	WEST
1	101	RANDALL	90+93.54	49.00 LT			A		TY24 F&G	900.17		896.17		
1	102	RANDALL	90+93.48	56.08 LT	A4				TY1 CLOSED LID	900.13			894.97	896.13
1	103	RANDALL	91+83.48	56.85 LT	A4				TY1 CLOSED LID	898.28	893.68		893.68	894.31
1	104	RANDALL	91+83.51	49.52 LT			A		TY24 F&G	898.36		894.36		
1	105	RANDALL	90+97.63	50.71 RT			A		TY24 F&G	900.71				896.71
1	106	RANDALL	90+97.42	57.87 RT	A4				TY1 CLOSED LID	899.96		896.67	895.29	
1	107	RANDALL	91+87.62	60.46 RT	A4				TY1 CLOSED LID	897.86	894.00	894.41	894.00	
1	108	RANDALL	91+87.84	53.13 RT			A		TY24 F&G	898.46				894.46
1	109	RANDALL	86+34.69	60.90 RT				FLARED END, 12"	-					

PROPOSED DRAINAGE STRUCTURE TABLE													
SHEET	STRUCT. NO.	ALIGN	STATION	OFFSET (FT)	STRUCTURE TYPE / SIZE			FRAME AND GRATE OR LID	RIM ELEV (FT)	INVERT ELEVATIONS			
					MH	CB	INL			OTHER	NORTH	EAST	SOUTH
3	201	RANDALL	92+73.53	50.70 LT			A	TY24 F&G	896.80		892.80		
3	202	RANDALL	92+73.41	58.04 LT	A4			TY1 CLOSED LID	896.74	892.76		892.76	892.76
3	203	RANDALL	93+63.75	52.52 LT			A	TY24 F&G	895.86		892.36		
3	204	RANDALL	93+63.64	61.85 LT	A4			TY1 CLOSED LID	895.25	892.30		892.30	892.30
3	205	RANDALL	94+54.16	53.01 LT		A5		TY24 F&G	895.50		892.00		892.00
3	206	RANDALL	94+54.07	63.01 LT	A6			TY1 CLOSED LID	894.91	891.94		891.94	891.94
3	207	RANDALL	95+34.80	54.13 LT			A	TY24 F&G	895.88		892.38		
3	208	RANDALL	95+34.72	63.46 LT	A5			TY1 CLOSED LID	894.84	891.54		891.54	892.31
3	209	RANDALL	96+01.85	54.93 LT			A	TY24 F&G	894.64		890.64		
3	210	RANDALL	96+09.67	64.35 LT	A4			TY1 CLOSED LID	896.15	891.19	882.11	890.50	890.55
3	211	RANDALL	96+57.47	125.54 LT				FLARED END, 24"	-				881.00
3	212	RANDALL	96+63.82	54.80 LT		A4		TY24 F&G	897.65		890.87		890.87
3	213	RANDALL	96+63.74	64.80 LT	A4			TY1 CLOSED LID	897.31	890.81		893.26	890.81
3	214	RANDALL	92+78.01	54.74 RT		A4		TY24 F&G	896.77				893.27
3	215	RANDALL	92+77.75	62.73 RT	A4			TY1 CLOSED LID	896.31	893.10	893.22	893.10	
3	216	RANDALL	93+67.95	59.05 RT			A	TY24 F&G	895.70				892.70
3	217	RANDALL	93+67.61	66.50 RT	A4			TY1 CLOSED LID	896.03	892.65	892.65	892.65	
3	218	RANDALL	92+81.97	66.91 RT				FLARED END, 36"	-			893.25	
3	219	RANDALL	93+58.34	89.38 RT				FLARED END, 36"	-		892.72		
3	220	RANDALL	94+57.14	70.94 RT	A4			TY1 CLOSED LID	895.65	892.29	892.29		
3	221	RANDALL	94+57.56	62.95 RT		A4		TY24 F&G	895.30		892.25		892.25
3	222	RANDALL	94+55.48	4.84 LT		A4		TY11 F&G	896.63	892.09	892.09		892.09
3	223	RANDALL	93+65.85	3.55 RT			A	TY11 F&G	897.01			892.54	
3	224	RANDALL	95+59.12	68.86 RT	A4			TY1 CLOSED LID	896.19		891.83	891.83	
3	225	RANDALL	95+58.98	61.61 RT			A	TY24 F&G	895.83				891.88
3	226	RANDALL	96+03.87	68.16 RT	A4			TY1 CLOSED LID	896.81	891.56	892.52	891.56	
3	227	RANDALL	96+03.70	60.83 RT			A	TY24 F&G	896.57				892.57
3	228	RANDALL	96+65.03	67.39 RT	A4			TY1 CLOSED LID	897.88	891.27	891.27	893.56	
3	229	RANDALL	96+65.00	59.39 RT		A4		TY24 F&G	897.56		891.23		891.23
3	230	RANDALL	96+64.29	12.92 LT		A4		TY11 F&G	898.64		890.98		890.98

PROPOSED DRAINAGE STRUCTURE TABLE														
SHEET	STRUCT. NO.	ALIGN	STATION	OFFSET (FT)	STRUCTURE TYPE / SIZE			FRAME AND GRATE OR LID	RIM ELEV (FT)	INVERT ELEVATIONS				
					MH	CB	INL			OTHER	NORTH	EAST	SOUTH	WEST
5	301	RANDALL	97+82.52	57.26 LT			A		TY24 F&G	899.64		895.64		
5	302	RANDALL	97+82.18	67.25 LT	A4				TY1 CLOSED LID	898.83	894.44			895.57
5	303	RANDALL	98+63.90	59.49 LT		A5			TY24 F&G	900.59		886.38		894.00
5	304	RANDALL	98+20.32	144.62 LT				FLARED END, 30"	-					885.00
5	305	RANDALL	100+01.63	108.52 LT			A		TY11 F&G	898.06		887.80		
5	306	RANDALL	100+50.94	107.98 LT		A5			TY24 F&G	897.20		886.73	890.97	
5	307	RANDALL	100+79.93	75.14 LT	A5				TY1 CLOSED LID	900.71	891.41		896.11	894.00
5	308	RANDALL	101+15.52	67.10 LT		A4			TY24 F&G	901.66	896.47		896.47	
5	309	RANDALL	102+08.24	67.04 LT		A4			TY24 F&G	902.57	897.40		897.40	897.40
5	310	RANDALL	103+10.27	67.80 LT			A		TY24 F&G	903.44	898.42			
5	311	RANDALL	97+82.79	59.51 RT			A		TY24 F&G	899.70				895.70
5	312	RANDALL	97+82.78	66.77 RT	A4				TY1 CLOSED LID	899.92	894.74	895.65		
5	313	RANDALL	98+82.08	62.70 RT		A5			TY24 F&G	900.92		894.60	894.60	
5	314	RANDALL	99+21.24	85.41 RT	A5				TY1 CLOSED LID	904.43	896.03		901.00	897.90
5	315	RANDALL	99+34.56	135.20 RT		A5			TY11 F&G	906.25		898.25		899.75
5	316	RANDALL	99+77.46	91.29 RT		A5			TY11 F&G	905.79	901.80			901.80
5	317	RANDALL	99+76.03	157.20 RT			A		TY11 F&G	907.69		902.79		
5	318	RANDALL	100+46.07	102.99 RT		A5			TY24 F&G	905.10		895.90		898.60
5	319	RANDALL	100+78.70	62.91 RT	A5				TY1 CLOSED LID	901.86		895.38	897.54	895.38
5	320	RANDALL	100+80.01	7.17 RT		A5			TY11 F&G	902.67		894.80		894.80
5	321	RANDALL	101+43.18	50.59 RT			A		TY24 F&G	902.23	898.20			
5	322	RANDALL	102+08.01	55.84 RT	A4				TY1 CLOSED LID	903.15		897.97	897.97	
5	323	RANDALL	102+07.99	47.77 RT		A4			TY24 F&G	902.84		897.93		897.93
5	324	RANDALL	102+08.02	4.96 RT		A4			TY11 F&G	903.61		897.76		897.76
5	325	RANDALL	103+11.12	55.47 RT	A4				TY1 CLOSED LID	904.03	899.00	899.00		
5	326	RANDALL	103+11.10	47.47 RT			A		TY24 F&G	903.73				899.05

PROPOSED DRAINAGE PIPE TABLE										
SHEET	PIPE NO.	STRUCTURE		DESCRIPTION	CLASS	TYPE	DIA. (IN)	LENGTH (FT)	SLOPE (%)	TBF (CF)
		FROM	TO							
1	S101	101	102	STORM SEWER	A	2	12	4.4	0.9	1.0
1	S102	102	103	STORM SEWER	A	2	12	86.0	1.5	0.0
1	S103	104	103	STORM SEWER	A	2	12	4.7	1.1	1.1
1	S104	105	106	STORM SEWER	A	2	12	4.5	0.9	0.8
1	S105	106	107	STORM SEWER	A	2	12	86.2	1.5	0.0
1	S106	108	107	STORM SEWER	A	2	12	4.7	1.0	0.9

PROPOSED DRAINAGE PIPE TABLE										
SHEET	PIPE NO.	STRUCTURE		DESCRIPTION	CLASS	TYPE	DIA. (IN)	LENGTH (FT)	SLOPE (%)	TBF (CF)
		FROM	TO							
3	S201	103	202	STORM SEWER	A	2	12	85.9	1.1	0.0
3	S202	201	202	STORM SEWER	A	2	12	4.7	0.9	1.1
3	S203	202	204	STORM SEWER	A	2	12	86.0	0.5	0.0
3	S204	203	204	STORM SEWER	A	2	12	6.7	0.9	1.0
3	S205	204	206	STORM SEWER	A	2	12x18	85.9	0.4	0.0
3	S206	205	206	STORM SEWER	A	2	19x30	4.4	1.0	1.2
3	S207	206	208	STORM SEWER	A	2	19x30	74.7	0.5	0.0
3	S208	207	208	STORM SEWER	A	2	12	6.7	1.0	0.8
3	S209	208	210	STORM SEWER	A	2	18	70.5	0.5	0.0
3	S210	209	210	STORM SEWER	A	2	12	9.3	1.0	2.9
3	S211	210	211	STORM SEWER	A	2	24	73.5	0.8	0.0
3	S212	212	213	STORM SEWER	A	2	18	6.0	1.0	3.6
3	S213	213	210	STORM SEWER	A	2	18	49.8	0.6	0.0
3	S214	302	213	STORM SEWER	A	2	12	113.8	1.0	0.0
3	S215	107	215	STORM SEWER	A	2	12	86.2	1.0	0.0
3	S216	214	215	STORM SEWER	A	2	12	4.9	1.0	0.8
3	S217	215	217	STORM SEWER	A	2	12	86.3	0.5	23.5
3	S218	216	217	STORM SEWER	A	2	12	4.8	1.0	1.3
3	S219	218	219	PIPE CULVERT	A	1	36	84.2	1.0	-13.2
3	S220	217	220	STORM SEWER	A	2	12x18	86.2	0.4	26.9
3	S221	220	221	STORM SEWER	A	2	12x18	4.0	1.0	1.2
3	S222	221	222	STORM SEWER	A	2	12x18	63.8	0.3	14.8
3	S223	223	222	STORM SEWER	A	2	12	86.0	0.5	24.4
3	S224	222	205	STORM SEWER	A	2	14x23	43.7	0.2	12.3
3	S225	EX	RET. WALL	STORM SEWER	A	2	48	12.1		0.0
3	S226	225	224	STORM SEWER	A	2	12	4.6	1.1	1.7
3	S227	224	226	STORM SEWER	A	2	12	41.0	0.7	17.7
3	S228	227	226	STORM SEWER	A	2	12	4.7	1.1	1.7
3	S229	226	228	STORM SEWER	A	2	12	57.5	0.5	31.4
3	S230	228	229	STORM SEWER	A	2	15	4.0	1.0	2.7
3	S231	229	230	STORM SEWER	A	2	15	68.3	0.4	41.1
3	S232	230	212	STORM SEWER	A	2	15	37.9	0.2	23.7
3	S233	312	228	STORM SEWER	A	2	12	114.4	1.0	49.2

MODEL: Default
FILE NAME: W:\894-088 Randall at Higgins Phase II Engineering\CADD Sheets\011 Drainage and Utilities Plans\18c00514c0b-WR TABLES.dgn

PROPOSED DRAINAGE STRUCTURE TABLE														
SHEET	STRUCT. NO.	ALIGN	STATION	OFFSET (FT)	STRUCTURE TYPE / SIZE			FRAME AND GRATE OR LID	RIM ELEV (FT)	INVERT ELEVATIONS				
					MH	CB	INL			OTHER	NORTH	EAST	SOUTH	WEST
7	401	RANDALL	105+28.56	57.28 LT			A		TY24 F&G	903.37			898.85	
7	402	RANDALL	105+91.72	53.98 LT		A4			TY24 F&G	902.64	898.22		898.22	
7	403	RANDALL	106+56.92	52.95 LT		A4			TY24 F&G	901.74	897.57		897.57	
7	404	RANDALL	107+20.84	51.60 LT		A4			TY24 F&G	900.60	896.53			895.53
7	405	RANDALL	107+13.78	64.09 LT				FLARED END, 18"	-				897.68	
7	406	RANDALL	107+69.51	65.87 LT				FLARED END, 18"	-		897.39			
7	407	RANDALL	107+99.88	51.39 LT			A		TY24 F&G	898.66		894.66		
7	408	RANDALL	108+00.00	59.39 LT	A4				TY1 CLOSED LID	897.90			892.52	894.62
7	409	RANDALL	109+42.47	56.31 LT	A4				TY1 CLOSED LID	893.64	890.45		888.64	890.45
7	410	RANDALL	109+42.26	48.31 LT			A		TY24 F&G	894.45		890.50		
7	411	RANDALL	105+27.65	47.69 RT			A		TY24 F&G	903.46				899.20
7	412	RANDALL	105+27.61	55.03 RT	A4				TY1 CLOSED LID	903.82		899.15	899.15	
7	413	RANDALL	105+92.66	48.30 RT			A		TY24 F&G	902.87				898.55
7	414	RANDALL	105+92.57	55.63 RT	A4				TY1 CLOSED LID	903.09	898.50	898.50	898.50	
7	415	RANDALL	106+55.11	49.19 RT			A		TY24 F&G	901.86				896.93
7	416	RANDALL	106+54.95	58.52 RT	A4				TY1 CLOSED LID	902.18	897.86	896.86	896.86	
7	417	RANDALL	107+19.06	57.80 RT	A4				TY1 CLOSED LID	900.79	896.28	894.44	894.44	
7	418	RANDALL	107+18.97	49.80 RT		A4			TY24 F&G	900.53		894.48		894.48
7	419	RANDALL	107+19.98	15.61 LT		A4			TY11 F&G	901.34	895.00	895.00		895.00
7	420	RANDALL	105+92.10	6.53 LT			A		TY11 F&G	903.64			897.05	
7	421	RANDALL	107+96.55	49.46 RT			A		TY24 F&G	898.66				894.66
7	422	RANDALL	107+96.58	57.14 RT	A4				TY1 CLOSED LID	898.96	893.66	894.61	893.66	
7	423	RANDALL	109+36.92	47.55 RT			A		TY24 F&G	894.56				890.56
7	424	RANDALL	109+38.16	55.15 RT	A4				TY1 CLOSED LID	894.91	891.59	890.61	889.06	

PROPOSED DRAINAGE STRUCTURE TABLE														
SHEET	STRUCT. NO.	ALIGN	STATION	OFFSET (FT)	STRUCTURE TYPE / SIZE				FRAME AND GRATE OR LID	RIM ELEV (FT)	INVERT ELEVATIONS			
					MH	CB	INL	OTHER			NORTH	EAST	SOUTH	WEST
9	501	RANDALL	110+84.70	51.57 LT	A4				TY1 CLOSED LID	890.58	887.22			887.02
9	502	RANDALL	111+00.11	63.88 LT				FLARED END, 18"	-				886.12	
9	503	RANDALL	111+46.54	61.43 LT				FLARED END, 18"	-		886.56			
9	504	RANDALL	112+26.26	44.48 LT			A		TY24 F&G	888.87		884.98		
9	505	RANDALL	112+26.14	54.28 LT				FLARED END, 12"	-					884.91
9	506	RANDALL	112+95.89	45.82 LT		A4			TY24 F&G	888.27		884.63		884.63
9	507	RANDALL	112+84.10	58.55 LT				FLARED END, 18"	-				885.43	
9	508	RANDALL	112+96.33	58.06 LT	A4				TY1 CLOSED LID	888.00	885.34		884.57	884.57
9	509	RANDALL	113+17.76	57.96 LT		A4			TY24 F&G	887.33	884.40		884.40	
9	510	RANDALL	110+79.76	76.18 RT				FLARED END, 19"x30"	-			886.59		
9	511	RANDALL	110+79.78	54.81 RT	A6				TY1 CLOSED LID	889.57	886.65	886.75		886.65
9	512	RANDALL	110+79.75	46.81 RT		A5			TY24 F&G	890.95		886.79		886.79
9	513	RANDALL	110+84.80	43.44 LT		A4			TY24 F&G	891.00		886.98		886.98
9	514	RANDALL	112+22.73	47.05 RT			A		TY24 F&G	888.75			885.43	
9	515	RANDALL	112+92.65	45.53 RT		A4			TY24 F&G	888.22	885.08	885.08		
9	516	RANDALL	113+27.99	77.77 RT				FLARED END, 24"	-				885.85	
9	517	RANDALL	113+64.26	56.41 RT				FLARED END, 24"	-		885.51			
9	518	RANDALL	116+50.28	51.62 RT				FLARED END, 24"	-				883.90	
9	519	RANDALL	116+90.00	51.13 RT				FLARED END, 24"	-		883.70			

PROPOSED DRAINAGE STRUCTURE TABLE														
SHEET	STRUCT. NO.	ALIGN	STATION	OFFSET (FT)	STRUCTURE TYPE / SIZE			FRAME AND GRATE OR LID	RIM ELEV (FT)	INVERT ELEVATIONS				
					MH	CB	INL			OTHER	NORTH	EAST	SOUTH	WEST
11	701	IL-72	189+39.17	43.68 LT		A5			TY24 F&G	920.11		910.70		911.30
11	702	IL-72	191+53.14	42.51 LT		A5			TY24 F&G	917.97		910.00		910.00
11	703	IL-72	188+96.12	39.85 RT		A4			TY24 F&G	920.50		916.50		916.50
11	704	IL-72	191+49.78	47.84 RT	A4				TY1 CLOSED LID	918.53	914.67	914.53		914.53
11	705	IL-72	191+50.22	38.47 RT			A		TY24 F&G	918.24			914.74	
11	706	IL-72	192+95.39	54.52 RT	A4				TY1 CLOSED LID	916.56	912.32	912.32		912.32
11	707	IL-72	192+95.50	47.26 RT			A		TY24 F&G	915.87			912.37	
11	708	IL-72	192+85.35	10.72 LT			A		TY11 F&G	916.88		912.18		

PROPOSED DRAINAGE STRUCTURE TABLE														
SHEET	STRUCT. NO.	ALIGN	STATION	OFFSET (FT)	STRUCTURE TYPE / SIZE				FRAME AND GRATE OR LID	RIM ELEV (FT)	INVERT ELEVATIONS			
					MH	CB	INL	OTHER			NORTH	EAST	SOUTH	WEST
13	801	IL-72	193+51.57	46.83 LT		A5			TY24 F&G	914.77		908.13		909.40
13	802	IL-72	195+64.13	47.43 LT		A5			TY24 F&G	911.85		905.40	907.80	906.00
13	803	IL-72	197+14.36	47.87 LT		A5			TY24 F&G	909.49		901.25	905.45	903.90
13	804	IL-72	193+95.49	56.12 RT	A4				TY1 CLOSED LID	916.11	910.77	910.77		910.77
13	805	IL-72	193+95.70	49.79 RT			A		TY24 F&G	914.31			910.81	
13	806	IL-72	194+95.63	62.23 RT	A4				TY1 CLOSED LID	915.04	909.04	909.04		909.04
13	807	IL-72	194+95.91	52.90 RT			A		TY24 F&G	912.61			909.11	
13	808	IL-72	195+96.37	64.18 RT	A4				TY1 CLOSED LID	912.54	907.66	907.66		907.66
13	809	IL-72	195+96.54	54.87 RT			A		TY24 F&G	911.23			907.73	
13	810	IL-72	196+95.97	64.58 RT	A5				TY1 CLOSED LID	911.42	906.14	906.14		906.14
13	811	IL-72	196+95.99	55.25 RT			A		TY24 F&G	909.71			906.21	
13	812	IL-72	197+96.88	62.53 RT	A5				TY1 CLOSED LID	908.88	904.13	900.01		904.13
13	813	IL-72	197+96.87	55.27 RT			A		TY24 F&G	907.68			904.18	
13	814	IL-72	195+63.80	10.77 LT		A4			TY11 F&G	912.59	908.00			908.00
13	815	IL-72	197+20.16	11.24 LT		A4			TY11 F&G	910.14	905.65			

PROPOSED DRAINAGE PIPE TABLE											
SHEET	PIPE NO.	STRUCTURE		DESCRIPTION	CLASS	TYPE	DIA. (IN)	LENGTH (FT)	SLOPE (%)	TBF (CF)	
		FROM	TO								
7	S401	401	402	STORM SEWER	A	2	12	58.9	1.1	17.9	
7	S402	402	403	STORM SEWER	A	2	12	60.9	1.1	17.1	
7	S403	403	404	STORM SEWER	A	2	12	59.6	1.7	15.4	
7	S404	405	406	PIPE CULVERT	A	1	18	52.0	0.6	5.9	
7	S405	407	408	STORM SEWER	A	2	12	5.3	0.8	1.0	
7	S406	408	409	STORM SEWER	A	2	12	137.8	1.5	0.0	
7	S407	410	409	STORM SEWER	A	2	12	5.3	0.9	1.0	
7	S408	411	412	STORM SEWER	A	2	12	4.7	1.1	1.9	
7	S409	412	414	STORM SEWER	A	2	12	61.3	1.1	25.1	
7	S410	413	414	STORM SEWER	A	2	12	4.7	1.1	1.9	
7	S411	414	416	STORM SEWER	A	2	12	58.7	1.1	29.6	
7	S412	415	416	STORM SEWER	A	2	12	6.7	1.0	3.1	
7	S413	416	417	STORM SEWER	A	2	15	60.4	1.0	42.7	
7	S414	418	417	STORM SEWER	A	2	18	4.0	1.0	2.8	
7	S415	419	418	STORM SEWER	A	2	15	61.4	0.8	31.3	
7	S416	404	419	STORM SEWER	A	2	15	32.0	1.7	14.4	
7	S417	420	419	STORM SEWER	A	2	12	124.1	1.7	61.2	
7	S418	417	422	STORM SEWER	A	2	18	73.9	1.1	47.7	
7	S419	421	422	STORM SEWER	A	2	12	5.0	1.0	2.3	
7	S420	422	424	STORM SEWER	A	2	18	138.3	1.5	113.8	
7	S421	423	424	STORM SEWER	A	2	12	4.9	1.0	2.5	

PROPOSED DRAINAGE STRUCTURE TABLE														
SHEET	STRUCT. NO.	ALIGN	STATION	OFFSET (FT)	STRUCTURE TYPE / SIZE				FRAME AND GRATE OR LID	RIM	INVERT ELEVATIONS			
					MH	CB	INL	OTHER		ELEV (FT)	NORTH	EAST	SOUTH	WEST
15	901	IL-72	203+03.48	60.39 LT	A5				TY1 CLOSED LID	887.09	879.95		880.50	
15	902	IL-72	203+02.85	9.65 RT		A5			TY11 F&G	888.22	880.65		880.65	884.00
15	903	IL-72	203+02.54	47.76 RT		A5			TY24 F&G	887.50	881.00		882.83	
15	904	IL-72	203+02.51	57.33 RT	A6				TY1 CLOSED LID	888.83	881.09			882.30
15	905	IL-72	202+68.70	188.73 LT				FLARED END, 15"				876.00		
15	906	IL-72	202+72.43	114.18 LT				FLARED END, 30"	-				878.10	
15	907	IL-72	203+21.81	220.76 LT				FLARED END, 15"	-			871.50		
15	908	IL-72	202+87.82	194.86 LT	A6			RESTRICTOR, 72"	2-TY1 CLOSED LID	882.42		874.80		871.43
15	910	IL-72	203+21.65	220.63 LT				FLARED END, 15"	-					871.00
PROPOSED DRAINAGE STRUCTURE TABLE														
SHEET	STRUCT. NO.	ALIGN	STATION	OFFSET (FT)	STRUCTURE TYPE / SIZE				FRAME AND GRATE OR LID	RIM	INVERT ELEVATIONS			
					MH	CB	INL	OTHER		ELEV (FT)	NORTH	EAST	SOUTH	WEST
17	1001	IL-72	207+00.47	54.68 LT		A4			TY24 F&G	866.97		858.70		860.60
17	1002	IL-72	209+17.68	50.20 LT		A5			TY1 CLOSED LID	862.30			851.40	

NOTE
AN ADDITIONAL 100 FEET OF STORM SEWERS, CLASS A, TYPE 2, 12"
AND 3 ADDITIONAL MANHOLES, TYPE A, 4'-DIAMETER, TYPE 1 FRAME,
CLOSED LID HAVE BEEN INCLUDED IN THE CONTRACT TO USE AT THE
DISCRETION OF THE ENGINEER IF FIELD DRAIN TILES ARE ENCOUNTERED.

PROPOSED DRAINAGE PIPE TABLE											
SHEET	PIPE NO.	STRUCTURE		DESCRIPTION	CLASS	TYPE	DIA. (IN)	LENGTH (FT)	SLOPE (%)	TBF (CF)	
		FROM	TO								
15	S901	901	906	STORM SEWER	A	2	30	57.7	3.1	0.0	
15	S902	902	901	STORM SEWER	A	2	30	66.0	0.2	59.4	
15	S903	903	902	STORM SEWER	A	2	30	34.1	1.0	30.1	
15	S904	904	903	STORM SEWER	A	2	30	5.6	1.6	5.0	
15	S905	305	902	STORM SEWER	A	2	12	190.2	2.0	110.0	
15	S906	306	904	STORM SEWER	A	2	30	189.2	1.0	43.5	
15	S907	EX	1001	STORM SEWER	A	2	24	92.0	2.1	91.3	
15	S908	905	908	PIPE CULVERT	A	1	15	15.1	1.3	0.0	
15	S909	908	907	PIPE CULVERT	A	1	15	37.7	1.1	0.0	
PROPOSED DRAINAGE PIPE TABLE											
SHEET	PIPE NO.	STRUCTURE		DESCRIPTION	CLASS	TYPE	DIA. (IN)	LENGTH (FT)	SLOPE (%)	TBF (CF)	
		FROM	TO								
17	S1001	1001	EX	STORM SEWER	A	2	24	98.0	1.4	66.8	
17	S1002	1003	1002	STORM SEWER	A	2	12	3.5	1.4	3.5	

MODEL: Default
FILE NAME: W:\894-088 Randall at Higgins Phase II Engineering\CADD Sheets\011 Drainage and Utilities Plans\15c00514c0bvr TABLES.dgn



BLA, Inc.






USER NAME = cesario	DESIGNED - TN	REVISED -
	DRAWN - TN	REVISED -
PLOT SCALE = 48.0000' / in.	CHECKED - GJE	REVISED -
PLOT DATE = 6/19/2025	DATE - 02/15/2025	REVISED -

STATE OF ILLINOIS
DEPARTMENT OF TRANSPORTATION


RANDALL ROAD AT IL ROUTE 72 (HIGGINS ROAD)
DRAINAGE STRUCTURE AND PIPE TABLES

SCALE: NA SHEET 3 OF 3 SHEETS STA. TO STA.


F.A.P. RTE.:	SECTION	COUNTY	TOTAL SHEETS	SHEET NO.
0336	19-00514-00-WR	KANE	304	123
CONTRACT NO. 61L28				
ILLINOIS FED. AID PROJECT				

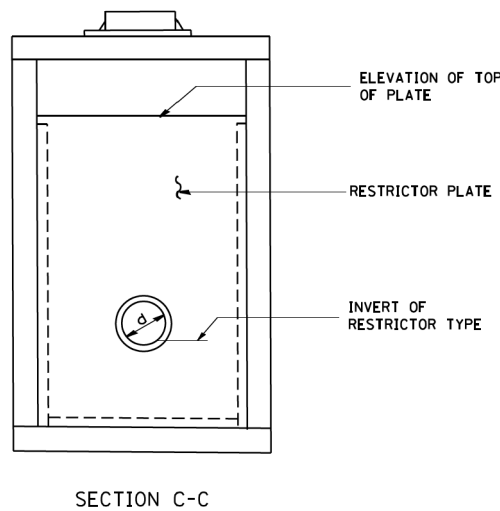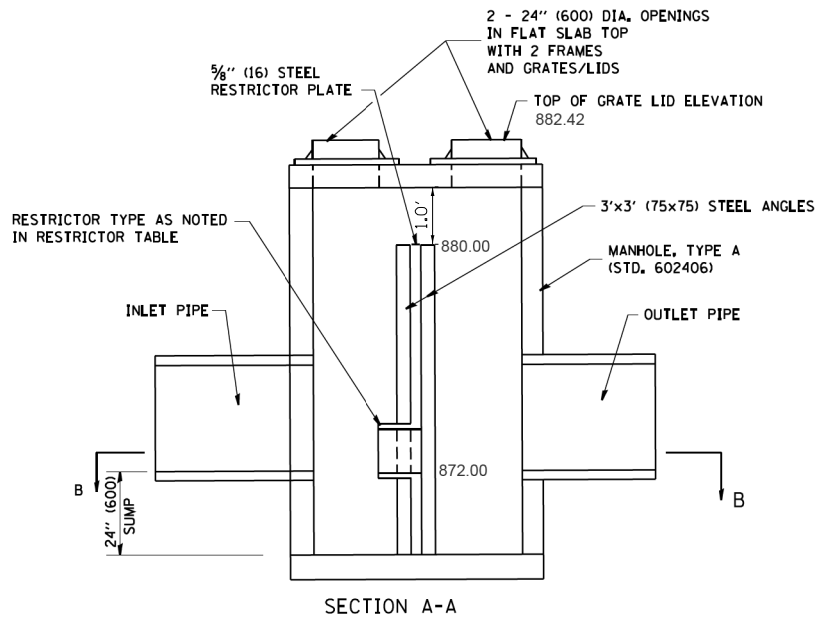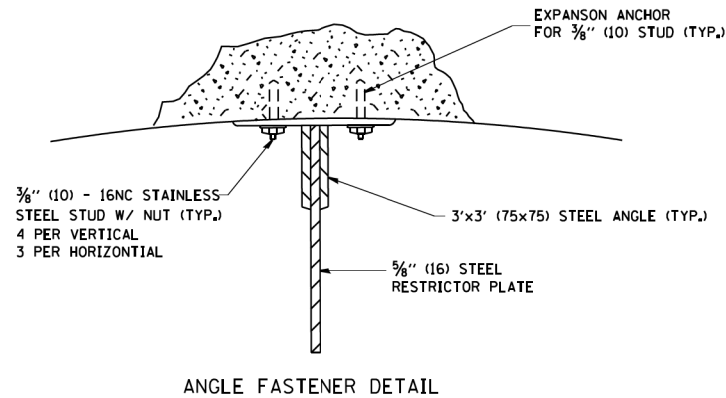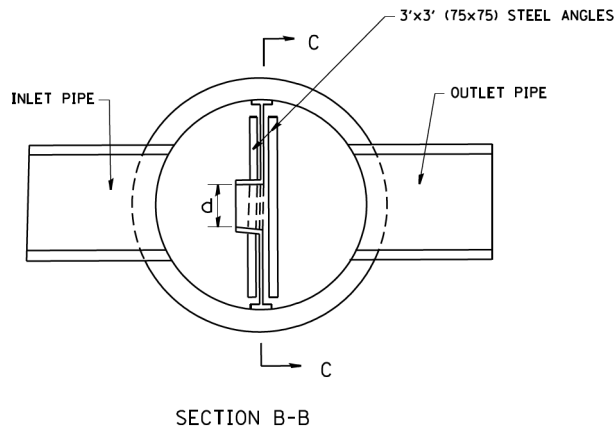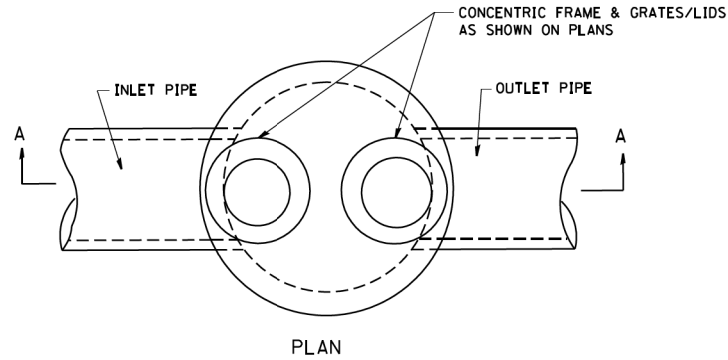

- NOTES:
1. ALL STEEL ANGLES AND PLATES TO BE GALVANIZED AFTER FABRICATION.
 2. ALL RESTRICTOR PLATES, ANGLES AND HARDWARE TO BE INCLUDED IN THE COST OF THE MANHOLE.
 3. BASIS OF PAYMENT: "MANHOLES, TYPE A, 6 FT. (1.8 m)-DIAMETER, TYPE 1 FRAME, CLOSED LID, RESTRICTOR PLATE" EACH

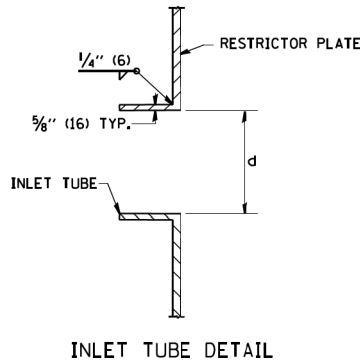

STATION	MANHOLE DIAMETER	FRAME AND GRATE	RESTRICTOR TYPE	INSIDE RESTRICTOR TYPE DIAMETER in. (mm) (d)	INVERT OF RESTRICTOR TYPE	ELEVATION OF TOP OF PLATE OVERFLOW
Randall 98+00.86, 292.79' LT	6"	2, TY 1 CLOSED LID	2	4"	872.00	880.00

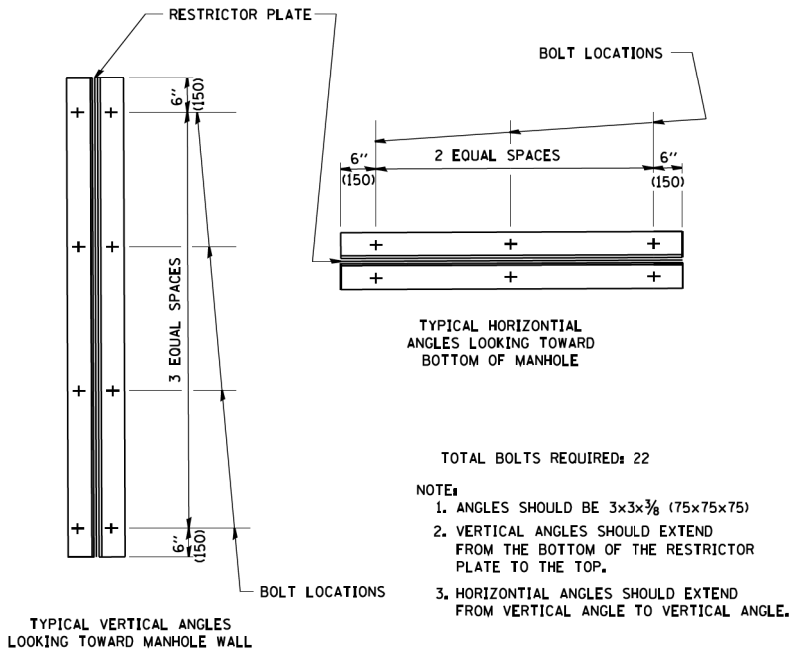


RESTRICTOR TYPE					
1	2	3	4	5	6
RE-ENTRANT TUBE	SHARP EDGED	SQUARE EDGED	RE-ENTRANT TUBE	SQUARE EDGED	ROUNDED
LENGTH: 1/2 TO 1 DIA.		STREAM CLEARS SIDES	LENGTH: 2-1/2 DIA.	LENGTH: 2-1/2 DIA.	
C=.52	C=.61	C=.61	C=.73	C=.82	C=.98

VALUES OF "C" FOR CIRCULAR AND SQUARE ORIFICES

STATE OF ILLINOIS
DEPARTMENT OF TRANSPORTATION
DIVISION OF HIGHWAYS


PLAT OF HIGHWAYS

ROUTE: RANDALL ROAD
SECTION: 19-00514-00-WR
COUNTY: KANE
LIMITS: RANDALL ROAD AT ILLINOIS ROUTE 72
JOB NO.: R-91-019-23

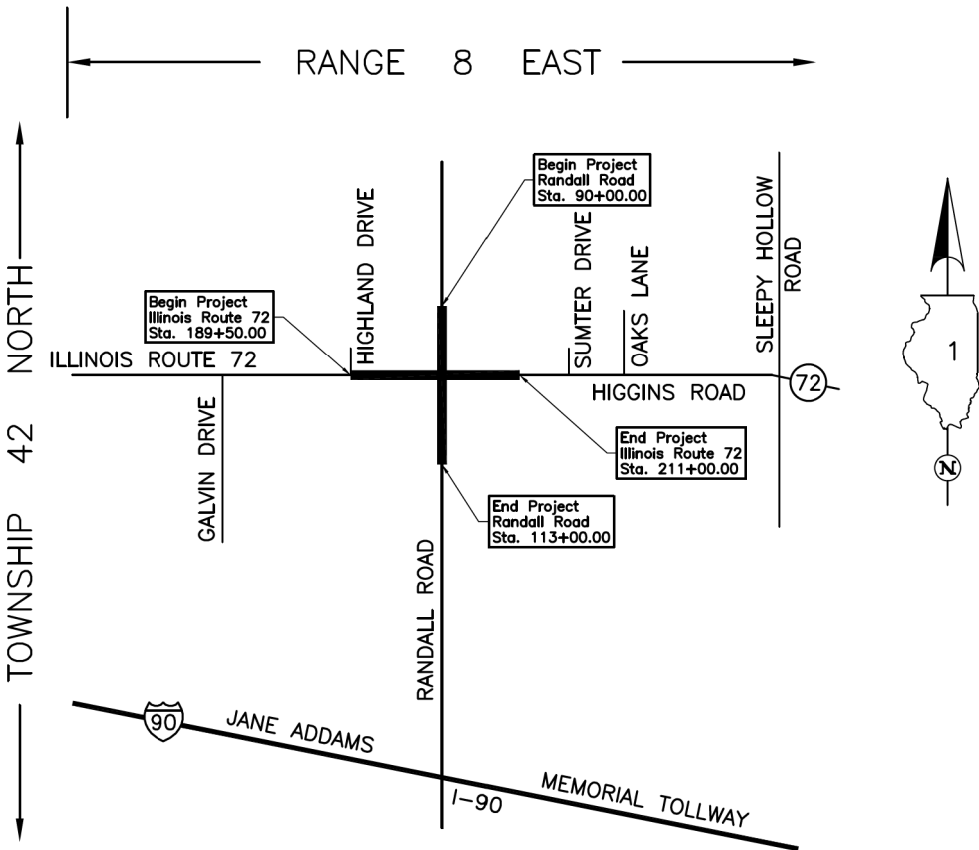

LOCATION MAP

PROJECT LENGTH = 2,300.00 LIN. FT. = 0.436 MILE, RANDALL ROAD
= 2,150.00 LIN. FT. = 0.407 MILE, ILLINOIS ROUTE 72
TOTAL LENGTH = 4,450.00 LIN. FT. = 0.843 MILE

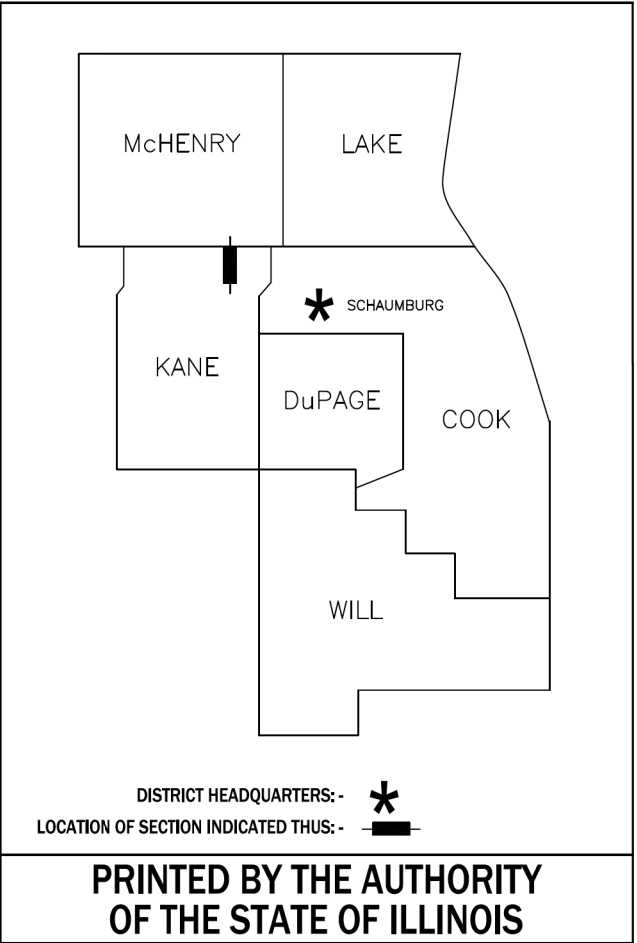

PARCEL NUMBER	OWNER	SHEET NUMBER	PROPERTY ACQUIRED BY
1PK0001-A 1PK0001-B 1PK0001-C 1PK0001-D	Scannell Properties #442, LLC, an Indiana limited liability company	2, 3, 4 & 7	
1PK0002	John Edmund Strepek, as Trustee of the John Edmund Strepek Trust dated March 20, 1995, as to an undivided 1/2 interest and Connie Lynn Strepek, as Trustee of the Connie Lynn Strepek Trust dated March 20, 1995, as to an undivided 1/2 interest	2 & 8	
1PK0003 1PK0003T.E.	Strepek Family, L.L.C., an Illinois limited liability company	3 & 8	
1PK0004	Lucky Holdings Ltd., an Illinois Corporation	5	
1PK0005 1PK0005T.E.	HJK Ventures, LLC, an Illinois limited liability company	6	

F.A.P RTE.	SECTION	COUNTY	TOTAL SHEETS	SHEET NO.
0336	19-00514-00-WR	KANE	304	125
CONTRACT NO.				

IDOT USE ONLY

PART OF THE SE 1/4 OF SEC. 19 AND PART OF THE SW 1/4 OF SEC. 20, TWP. 42 N., R. 8 E. OF THE 3RD. P.M., IN KANE COUNTY, ILLINOIS.

PARCEL NUMBER	TOTAL HOLDINGS ACRES	PART TAKEN ACRES	AREA IN EXISTING R.O.W. ACRES	REMAINDER AREA ACRES	EASEMENT AREA ACRES	EASEMENT PURPOSE	PERMANENT INDEX NUMBER
1PK0001-A 1PK0001-B 1PK0001-C 1PK0001-D	52.471	A=0.433 B=0.1116 C=0.057 D=0.032	N/A	51.833	N/A	N/A	03-19-400-021 03-19-400-023
1PK0002	4.971	0.047	N/A	4.924	N/A	N/A	03-20-300-005

See Sheet 7
for Total Holdings
Parcel 1PK0001-A, B, C & D

SECTION
CORNER

LEGEND



QUARTER
SECTION
CORNER

_____ SECTION LINE
 _____ QUARTER SECTION LINE
 _____ QUARTER, QUARTER SECTION LINE
 _____ PLATTED LOT LINE
 _____ P _____ PROPERTY (DEED) LINE

APL	APPARENT PROPERTY LINE
---	EXISTING CENTER LINE
---	PROPOSED CENTER LINE
---	EXISTING RIGHT OF WAY LINE
---	PROPOSED RIGHT OF WAY LINE
---	EXISTING EASEMENT
---	PROPOSED EASEMENT
AC	EXISTING ACCESS CONTROL LINE
AC	PROPOSED ACCESS CONTROL LINE
120.32'	MEASURED DIMENSION
129.32'(Comp.)	COMPUTED DIMENSION
(129.32')	RECORD DIMENSION

EXISTING BUILDING

SCALE: 1"=50'

Bearings and Coordinates are referenced to the
Illinois Coordinate System NAD 83(2011) East Zone

○	IRON PIPE OR ROD FOUND	⊕	"MAG" NAIL SET
+	CUT CROSS FOUND OR SET	●	5/8" REBAR SET

■ **STAKING OF PROPOSED RIGHT OF WAY.** SET DIVISION OF HIGHWAYS SURVEY MARKER TO MONUMENT THE POSITION SHOWN. IDENTIFIED BY INSCRIPTION DATA AND SURVEYORS REGISTRATION NUMBER.

■ M STAKING OF PROPOSED RIGHT OF WAY IN CULTIVATED AREAS. BURIED 5/8 INCH METAL ROD 20 INCHES BELOW GROUND TO MARK FUTURE SURVEY MARKER POSITION IDENTIFIED BY COLORED PLASTIC CAP BEARING SURVEYORS REGISTRATION NUMBER.

 PERMANENT SURVEY MARKER, I.D.O.T STD 667101-02 (TO BE SET BY OTHERS)

☐ RIGHT OF WAY STAKING PROPOSED TO BE SET.

STATE OF ILLINOIS)
COUNTY OF LAKE)SS

THIS IS TO CERTIFY THAT WE, JORGENSEN & ASSOCIATES, INC., AN ILLINOIS PROFESSIONAL DESIGN FIRM, LAND SURVEYING CORPORATION, NUMBER 184-2771, HAVE SURVEYED THE PLAT OF HIGHWAYS SHOWN HEREON BETWEEN SECTION 19, TOWNSHIP 42N., RANGE 8E. AND SECTION 20, TOWNSHIP 42N., RANGE 8E., OF THE THIRD PRINCIPAL MERIDIAN, KANE COUNTY, THAT THE SURVEY IS TRUE AND COMPLETE AS SHOWN TO THE BEST OF MY KNOWLEDGE AND BELIEF, THAT THE PLAT CORRECTLY REPRESENTS SAID SURVEY, THAT ALL MONUMENTS FOUND AND ESTABLISHED ARE OF PERMANENT QUALITY AND OCCUPY THE POSITIONS SHOWN THEREON AND THAT THE MONUMENTS ARE SUFFICIENT TO ENABLE THE SURVEY TO BE RETRACED. MADE FOR THE DEPARTMENT OF TRANSPORTATION, STATE OF ILLINOIS.

DATED AT LAKE VILLA, ILLINOIS THIS _____ DAY OF _____ 20__ A.D.

ILLINOIS PROFESSIONAL LAND SURVEYOR NO. 35-2797
LICENSE EXPIRATION DATE: NOVEMBER 30, 2024

THIS PROFESSIONAL SERVICE CONFORMS TO THE CURRENT ILLINOIS MINIMUM STANDARDS FOR A BOUNDARY SURVEY.

All dimensions are measured unless otherwise specified.

Areas shown on this plat are ground.
All measured and computed distances are grid not ground

To obtain ground distances, divide grid distances shown by the combined factor of 0.9999373150.

PROJECT COORDINATES			
Illinois Coordinate System NAD 83(2011) East Zone			
STATION	OFFSET	NORTH	EAST
108+70.61	79.14' Rt.	1,979,392.092	983,660.759
109+37.88	59.77' Rt.	1,979,325.251	983,682.832
109+37.93	78.74' Rt.	1,979,324.377	983,663.880
109+87.02	60.35' Lt.	1,979,281.598	983,805.048
110+49.61	89.00' Rt.	1,979,211.517	983,659.030
110+49.68	78.74' Rt.	1,979,211.989	983,669.280
110+76.71	89.00' Rt.	1,979,184.250	983,660.506
110+77.19	0.24' Lt.	1,979,188.703	983,749.633
110+77.19	59.76' Rt.	1,979,185.384	983,689.728

JORGENSEN & ASSOCIATES, INC.
120 PARK AVENUE
LAKE VILLA, ILLINOIS 60046
(847) 356-3371

PLAT OF HIGHWAYS
STATE OF ILLINOIS
DEPARTMENT OF TRANSPORTATION
RANDALL ROAD

LIMITS: RANDALL ROAD AT ILLINOIS ROUTE 72
COUNTY: KANE
SECTION: 19-00514-00-WR JOB NO.: R-91-019-23
STATION 108+00 TO STATION 117+82.42
SCALE: 1"=50' SHEET 2 OF 9

BUREAU OF LAND ACQUISITION
201 WEST CENTER COURT
SCHAUMBURG, ILLINOIS 60196

PROJECT COORDINATES			
Illinois Coordinate System		NAD 83(2011) East Zone	
STATION	OFFSET	NORTH	EAST
110+83.59	62.73' Lt.	1,979,185.721	983,812.386
110+83.88	70.00' Lt.	1,979,185.828	983,819.659
112+00.00	89.00' Rt.	1,979,062.069	983,666.607
113+16.06	60.42' Lt.	1,978,952.142	983,820.477
113+16.62	70.00' Lt.	1,978,951.902	983,830.075
114+14.30	125.20' Lt.	1,978,855.102	983,888.212
114+61.44	75.27' Lt.	1,978,806.377	983,839.429
115+00.00	84.00' Rt.	1,978,764.646	983,680.960
115+00.00	89.00' Rt.	1,978,764.555	983,675.961
116+49.47	84.00' Rt.	1,978,616.283	983,682.713
116+49.62	59.70' Rt.	1,978,616.258	983,707.015

F.A.P RTE.	SECTION		
0336	19-00514-00-WR		
COUNTY	TOTAL SHEETS	SHEET NO.	
KANE	304	126	
CONTRACT NO.			

IDOT USE ONLY

EXISTING R.O.W. RECORDED INFORMATION		
Parcel	Document No.	Date Recorded
1PK0001	96K017695	March 12, 1996
1PK0001	2011 ED 39	*September 19, 2011
1PK0002	95K076116	December 13, 1995
1PK0002	95K076117	December 13, 1995
----	570175	December 12, 1946
----	95K074957	December 7, 1995
----	98K103162	November 6, 1998


* Date Filed

REVISION DATE

REVISION


COUNTY, ILLINOIS. SEE SHEET 4

PARCEL NUMBER	TOTAL HOLDINGS ACRES	PART TAKEN ACRES	AREA IN EXISTING R.O.W. ACRES	REMAINDER AREA ACRES	EASEMENT AREA ACRES	EASEMENT PURPOSE	PERMANENT INDEX NUMBER
1PK0001-A 1PK0001-B 1PK0001-C 1PK0001-D	52.471	A=0.433 B=0.116 C=0.057 D=0.032	N/A	51.833	N/A	N/A	03-19-400-021 03-19-400-023
1PK0003 1PK0003.TE.	71.897	0.168	0.095	71.729	0.018	Construction Purposes	03-20-300-010

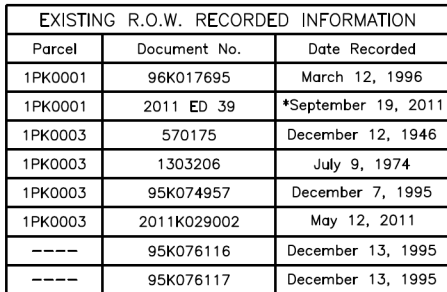* Date Filed

M-4
"Monument Record"

 East 1/4 Corner Section 19-42-8
N.1,980,276.536-E.983,780.703
Recorded
Document No.




-8 JORGENSEN & ASSOCIATES, INC.
-B 120 PARK AVENUE
-D LAKE VILLA, ILLINOIS 60046
(847) 356-3371

LIMITS: RANDALL ROAD AT ILLINOIS ROUTE 72
COUNTY: KANE
SECTION: 19-00514-00-WR JOB NO.: R-91-019-23
STATION 99+00 TO STATION 111+00
STATION 197+00 TO STATION 202+00
SCALE: 1"=50' SHEET 3 OF 9

**BUREAU OF LAND ACQUISITION
201 WEST CENTER COURT
SCHAUMBURG, ILLINOIS 60196**

PART OF THE EAST 1/2 OF SEC. 19, TWP. 42 N., R. 8 E. OF THE 3RD. P.M., IN KANE COUNTY, ILLINOIS.

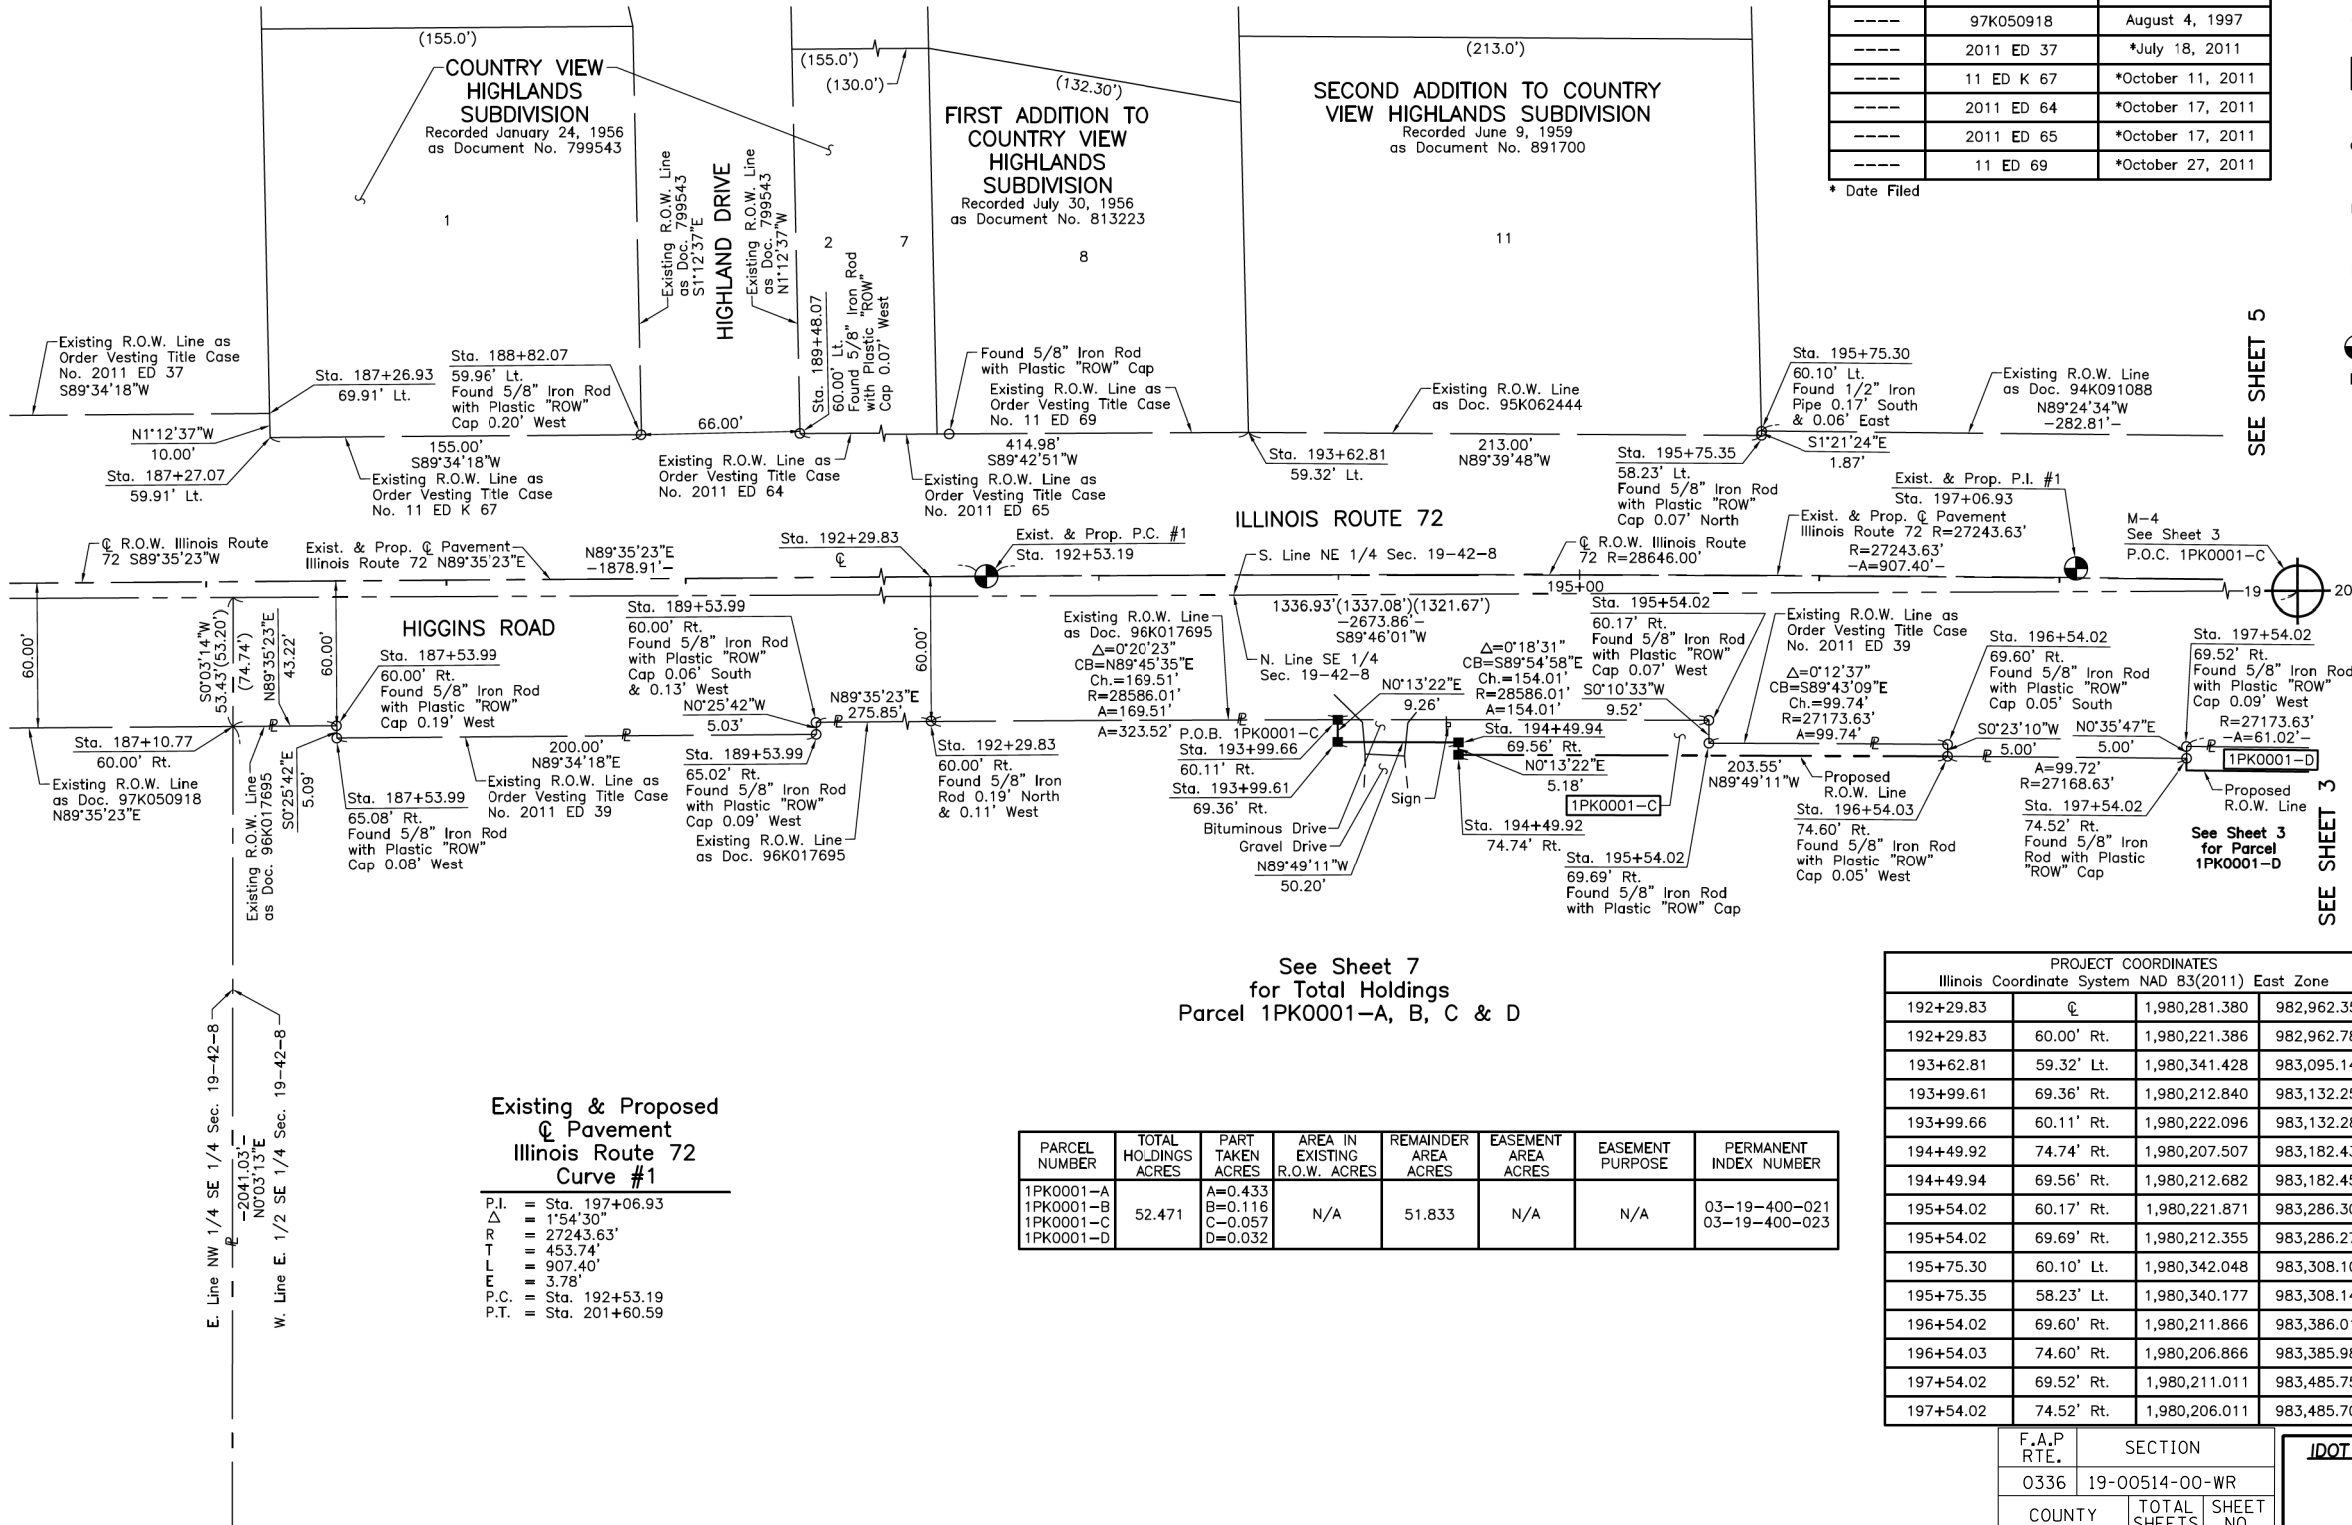

LEGEND

SECTION CORNER
QUARTER SECTION CORNER

SECTION LINE
QUARTER SECTION LINE
QUARTER, QUARTER SECTION LINE
PLATTED LOT LINE
PROPERTY (DEED) LINE

APL
APPARENT PROPERTY LINE
EXISTING CENTER LINE
PROPOSED CENTER LINE
EXISTING RIGHT OF WAY LINE
PROPOSED RIGHT OF WAY LINE
EXISTING EASEMENT
PROPOSED EASEMENT
EXISTING ACCESS CONTROL LINE
PROPOSED ACCESS CONTROL LINE
MEASURED DIMENSION
COMPUTED DIMENSION
RECORD DIMENSION

EXISTING BUILDING

Bearings and Coordinates are referenced to the Illinois Coordinate System NAD 83(2011) East Zone.

IRON PIPE OR ROD FOUND
CUT CROSS FOUND OR SET
STAKING OF PROPOSED RIGHT OF WAY. SET DIVISION OF HIGHWAYS SURVEY MARKER TO MONUMENT THE POSITION SHOWN, IDENTIFIED BY INSCRIPTION DATA AND SURVEYORS REGISTRATION NUMBER.
STAKING OF PROPOSED RIGHT OF WAY IN CULTIVATED AREAS. BURIED 5/8 INCH METAL ROD 20 INCHES BELOW GROUND TO MARK FUTURE SURVEY MARKER POSITION IDENTIFIED BY COLORED PLASTIC CAP BEARING SURVEYORS REGISTRATION NUMBER.
PERMANENT SURVEY MARKER, I.D.O.T STD 667101-02 (TO BE SET BY OTHERS)
RIGHT OF WAY STAKING PROPOSED TO BE SET.

STATE OF ILLINOIS }
COUNTY OF LAKE }SS

THIS IS TO CERTIFY THAT WE, JORGENSEN & ASSOCIATES, INC., AN ILLINOIS PROFESSIONAL DESIGN FIRM LAND SURVEYING CORPORATION, NUMBER 184-2771, HAVE SURVEYED THE PLAT OF HIGHWAYS SHOWN HEREON IN SECTION 19, TOWNSHIP 42N., RANGE 8E., OF THE THIRD PRINCIPAL MERIDIAN, KANE COUNTY, THAT THE SURVEY IS TRUE AND COMPLETE AS SHOWN TO THE BEST OF MY KNOWLEDGE AND BELIEF, THAT THE PLAT CORRECTLY REPRESENTS SAID SURVEY, THAT ALL MONUMENTS FOUND AND ESTABLISHED ARE OF PERMANENT QUALITY AND OCCUPY THE POSITIONS SHOWN THEREON AND THAT THE MONUMENTS ARE SUFFICIENT TO ENABLE THE SURVEY TO BE RETRACED. MADE FOR THE DEPARTMENT OF TRANSPORTATION, STATE OF ILLINOIS.

DATED AT LAKE VILLA, ILLINOIS THIS ____ DAY OF _____ 20__ A.D.

ILLINOIS PROFESSIONAL LAND SURVEYOR NO. 35-2797
LICENSE EXPIRATION DATE: NOVEMBER 30, 2024

THIS PROFESSIONAL SERVICE CONFORMS TO THE CURRENT ILLINOIS MINIMUM STANDARDS FOR A BOUNDARY SURVEY. All dimensions are measured unless otherwise specified. Areas shown on this plat are ground. All measured and computed distances are grid not ground. To obtain ground distances, divide grid distances shown by the combined factor of 0.9999373150.

PROJECT COORDINATES
Illinois Coordinate System NAD 83(2011) East Zone

STATION	OFFSET	NORTH	EAST
187+10.77	60.00' Rt.	1,980,217.670	982,443.733
187+26.93	69.91' Lt.	1,980,347.685	982,458.963
187+27.07	59.91' Lt.	1,980,337.687	982,459.174
187+53.99	60.00' Rt.	1,980,217.979	982,486.953
187+53.99	65.08' Rt.	1,980,212.891	982,486.991
188+82.07	59.96' Lt.	1,980,338.846	982,614.172
189+48.07	60.00' Lt.	1,980,339.357	982,680.172
189+53.99	60.00' Rt.	1,980,219.411	982,686.948
189+53.99	65.02' Rt.	1,980,214.386	982,686.986

JORGENSEN & ASSOCIATES, INC.
120 PARK AVENUE
LAKE VILLA, ILLINOIS 60046
(847) 356-3371

PLAT OF HIGHWAYS
STATE OF ILLINOIS
DEPARTMENT OF TRANSPORTATION
RANDALL ROAD
LIMITS: RANDALL ROAD AT ILLINOIS ROUTE 72
COUNTY: KANE
SECTION: 19-00514-00-WR JOB NO.: R-91-019-23
STATION 187+00 TO STATION 198+00
SCALE: 1"=40' SHEET 4 OF 9

BUREAU OF LAND ACQUISITION
201 WEST CENTER COURT
SCHAUMBURG, ILLINOIS 60196

EXISTING R.O.W. RECORDED INFORMATION		
Parcel	Document No.	Date Recorded
1PK0001	96K017695	March 12, 1996
1PK0001	2011 ED 39	*September 19, 2011
-----	799543	January 24, 1956
-----	94K091088	December 19, 1994
-----	95K062444	October 18, 1995
-----	97K050918	August 4, 1997
-----	2011 ED 37	*July 18, 2011
-----	11 ED K 67	*October 11, 2011
-----	2011 ED 64	*October 17, 2011
-----	2011 ED 65	*October 17, 2011
-----	11 ED 69	*October 27, 2011

* Date Filed


REVISION DATE

REVISION

PART OF THE EAST 1/2 OF SEC. 19 AND PART OF THE WEST 1/2 OF SEC. 20, TWP. 42 N., R. 8 E. OF THE 3RD. P.M., IN KANE COUNTY, ILLINOIS.

EXISTING R.O.W. RECORDED INFORMATION		
Parcel	Document No.	Date Recorded
1PK0004	94K091088	December 19, 1994
-----	570175	December 12, 1946
-----	918296	April 27, 1960
-----	1303206	July 9, 1974
-----	95K062444	October 18, 1995
-----	95K074957	December 7, 1995
-----	96K017698	March 12, 1996
-----	2010K077141	November 15, 2010
-----	2011K029002	May 12, 2011
-----	2011 ED 39	*September 19, 2011

* Date Filed

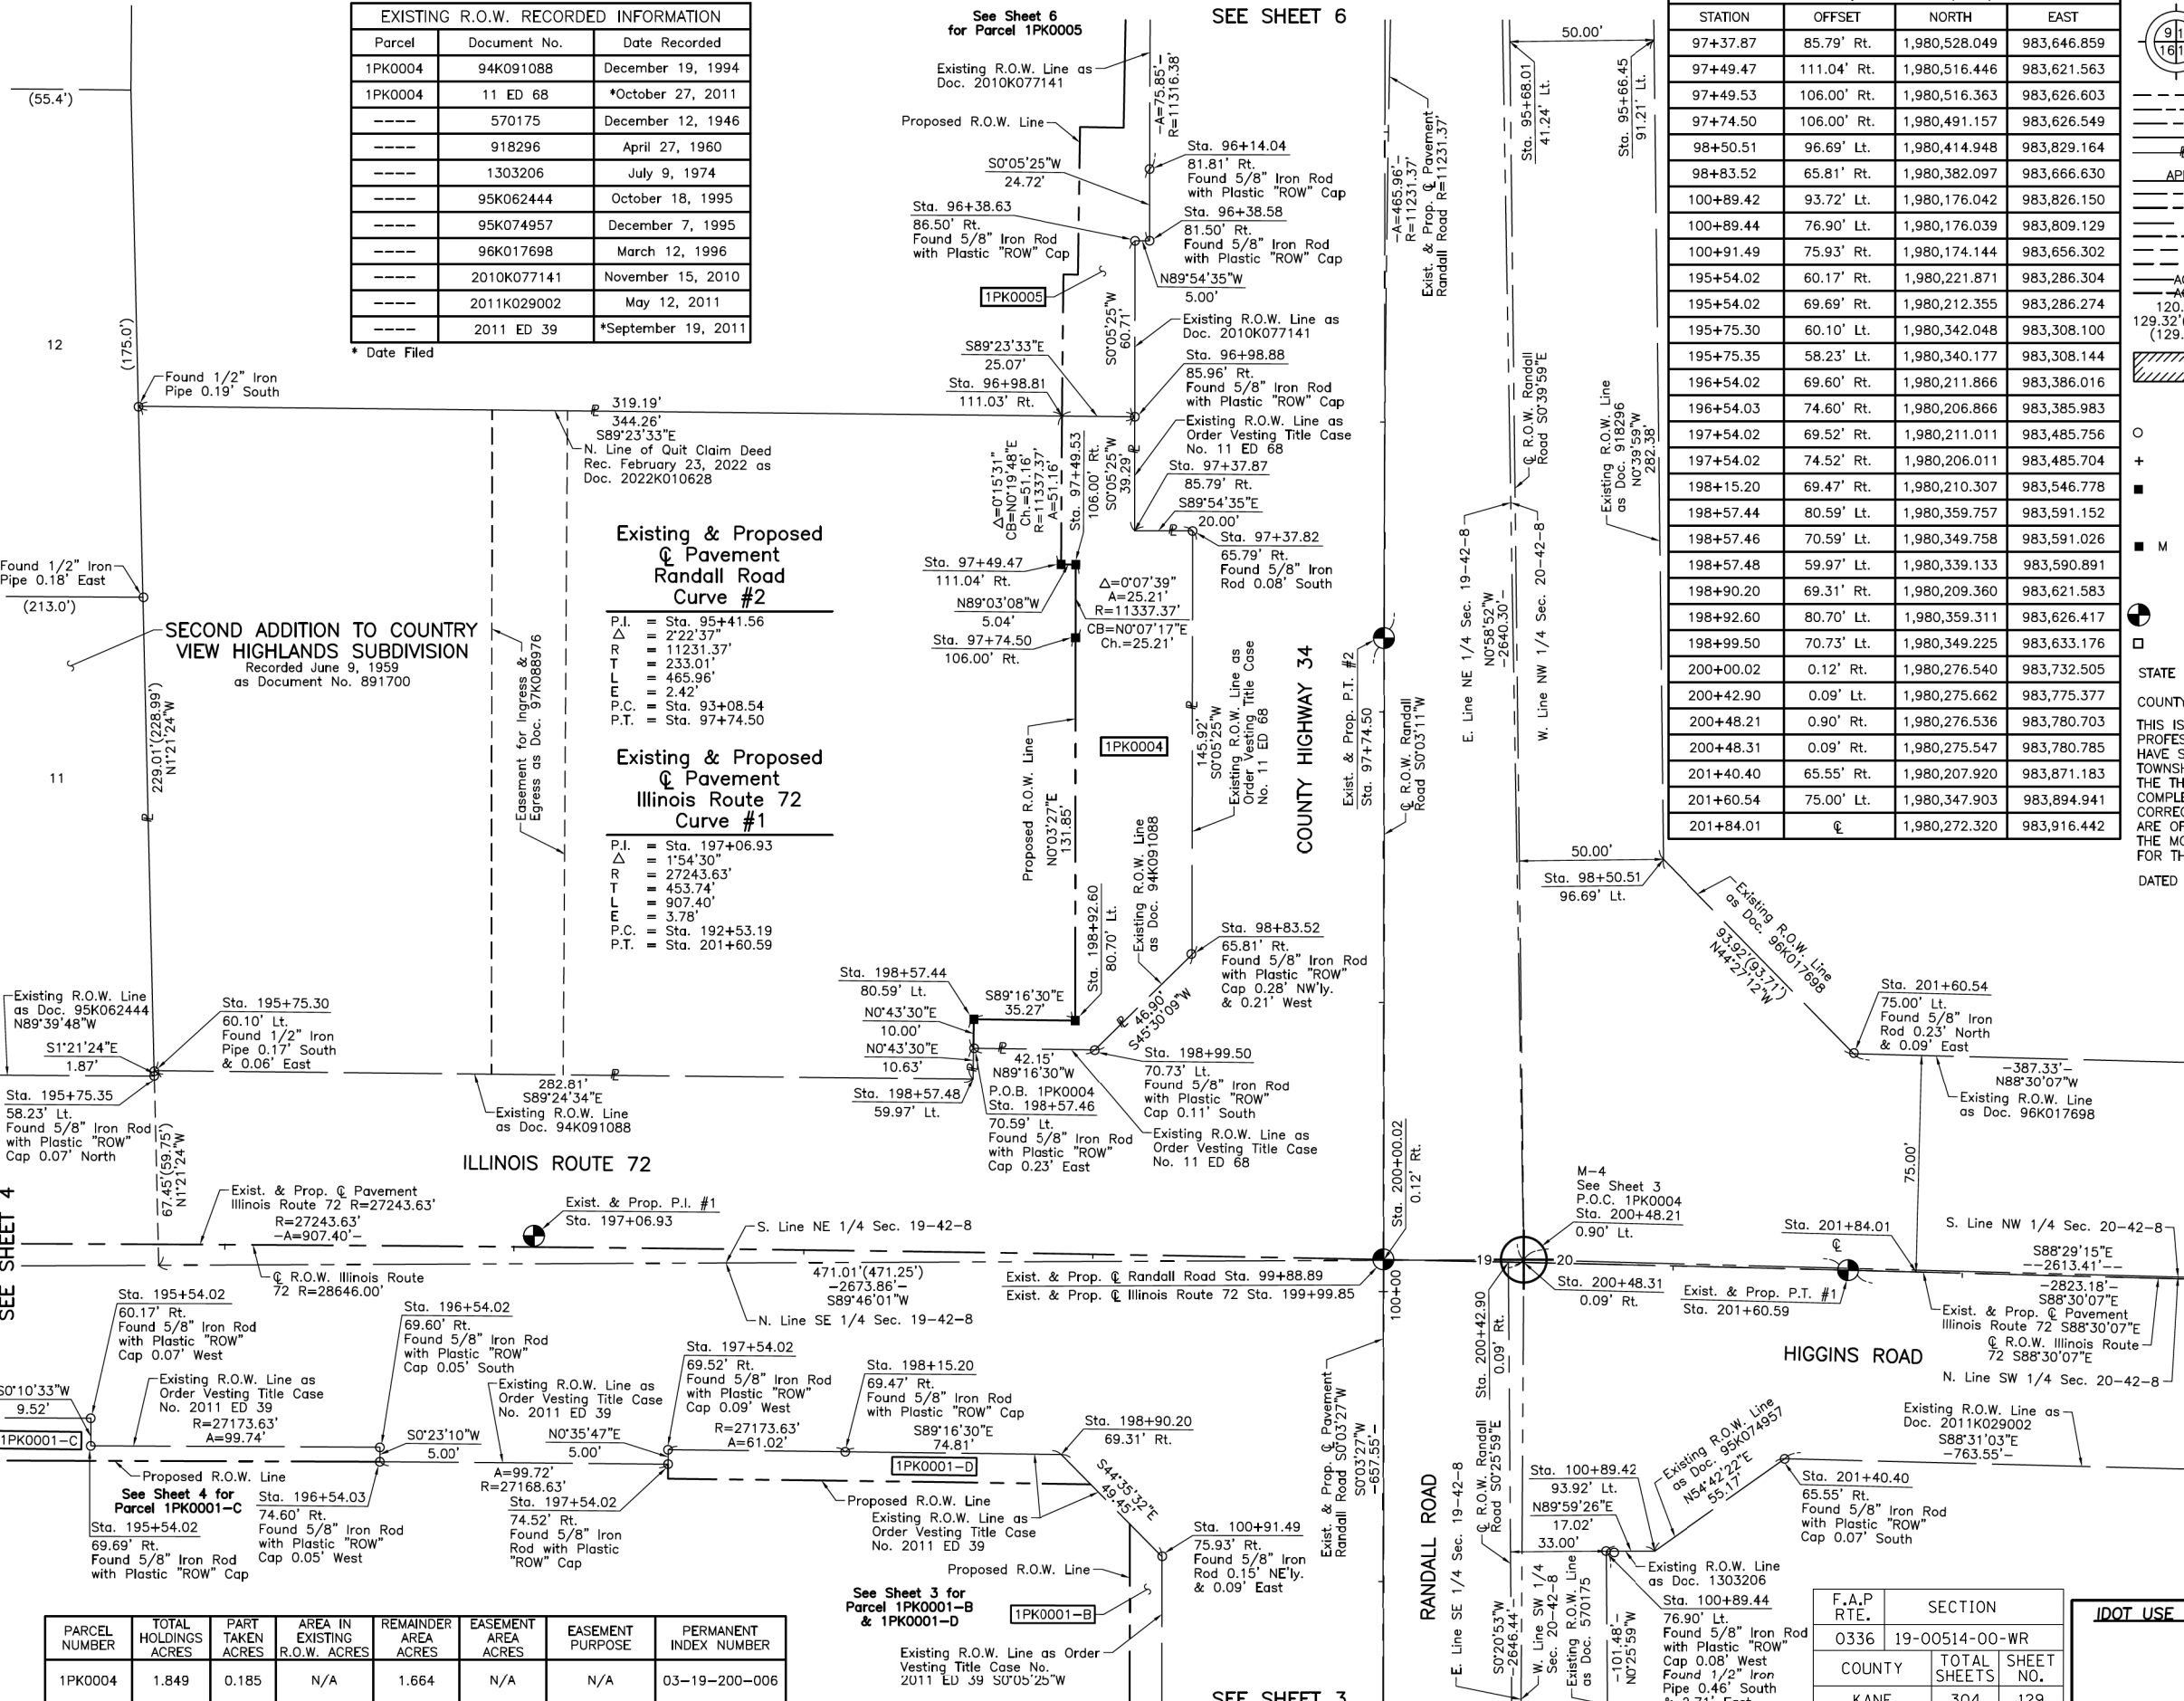

PROJECT COORDINATES Illinois Coordinate System NAD 83(2011) East Zone			
STATION	OFFSET	NORTH	EAST
97+37.87	85.79' Rt.	1,980,528.049	983,646.859
97+49.47	111.04' Rt.	1,980,516.446	983,621.563
97+49.53	106.00' Rt.	1,980,516.363	983,626.603
97+74.50	106.00' Rt.	1,980,491.157	983,626.549
98+50.51	96.69' Lt.	1,980,414.948	983,829.164
98+83.52	65.81' Rt.	1,980,382.097	983,666.630
100+89.42	93.72' Lt.	1,980,176.042	983,826.150
100+89.44	76.90' Lt.	1,980,176.039	983,809.129
100+91.49	75.93' Rt.	1,980,174.144	983,656.302
195+54.02	60.17' Rt.	1,980,221.871	983,286.304
195+54.02	69.69' Rt.	1,980,212.355	983,286.274
195+75.30	60.10' Lt.	1,980,342.048	983,308.100
195+75.35	58.23' Lt.	1,980,340.177	983,308.144
196+54.02	69.60' Rt.	1,980,211.866	983,386.016
196+54.03	74.60' Rt.	1,980,206.866	983,385.956
197+54.02	69.52' Rt.	1,980,211.011	983,485.783
197+54.02	74.52' Rt.	1,980,206.011	983,485.704
198+15.20	69.47' Rt.	1,980,210.307	983,546.778
198+57.44	80.59' Lt.	1,980,359.757	983,591.152
198+57.46	70.59' Lt.	1,980,349.758	983,591.026
198+57.48	59.97' Lt.	1,980,339.133	983,590.891
198+90.20	69.31' Rt.	1,980,209.360	983,621.583
198+92.60	80.70' Lt.	1,980,359.311	983,626.417
198+99.50	70.73' Lt.	1,980,349.225	983,633.176
200+00.02	0.12' Rt.	1,980,276.540	983,732.505
200+42.90	0.09' Lt.	1,980,275.662	983,775.377
200+48.21	0.90' Rt.	1,980,276.536	983,780.703
200+48.31	0.09' Rt.	1,980,275.547	983,780.785
201+40.40	65.55' Rt.	1,980,207.920	983,871.183
201+60.54	75.00' Lt.	1,980,347.903	983,894.941
201+84.01	0.00' Lt.	1,980,272.320	983,916.442

SECTION CORNER

QUARTER SECTION CORNER

SECTION LINE

QUARTER SECTION LINE

QUARTER SECTION LINE

PLATTED LOT LINE

PROPERTY (DEED) LINE

APL

APPARENT PROPERTY LINE

EXISTING CENTER LINE

PROPOSED CENTER LINE

EXISTING RIGHT OF WAY LINE

PROPOSED RIGHT OF WAY LINE

EXISTING EASEMENT

PROPOSED EASEMENT

EXISTING ACCESS CONTROL LINE

PROPOSED ACCESS CONTROL LINE

MEASURED DIMENSION

COMPUTED DIMENSION

RECORD DIMENSION

EXISTING BUILDING

Bearings and Coordinates are referenced to the Illinois Coordinate System NAD 83(2011) East Zone.

IRON PIPE OR ROD FOUND

CUT CROSS FOUND OR SET

STAKING OF PROPOSED RIGHT OF WAY. SET DIVISION OF HIGHWAYS SURVEY MARKER TO MONUMENT THE POSITION SHOWN. IDENTIFIED BY INSCRIPTION DATA AND SURVEYORS REGISTRATION NUMBER.

STAKING OF PROPOSED RIGHT OF WAY IN CULTIVATED AREAS. BURIED 5/8 INCH METAL ROD 20 INCHES BELOW GROUND TO MARK FUTURE SURVEY MARKER POSITION IDENTIFIED BY COLORED PLASTIC CAP BEARING SURVEYORS REGISTRATION NUMBER.

PERMANENT SURVEY MARKER, I.D.O.T STD 667101-02 (TO BE SET BY OTHERS)

RIGHT OF WAY STAKING PROPOSED TO BE SET.

STATE OF ILLINOIS

COUNTY OF LAKE

THIS IS TO CERTIFY THAT WE, JORGENSEN & ASSOCIATES, INC., AN ILLINOIS PROFESSIONAL DESIGN FIRM LAND SURVEYING CORPORATION, NUMBER 184-2771, HAVE SURVEYED THE PLAT OF HIGHWAYS SHOWN HEREON BETWEEN SECTION 19, TOWNSHIP 42N., RANGE 8E. AND SECTION 20, TOWNSHIP 42N., RANGE 8E., OF THE THIRD PRINCIPAL MERIDIAN, KANE COUNTY, THAT THE SURVEY IS TRUE AND COMPLETE AS SHOWN TO THE BEST OF MY KNOWLEDGE AND BELIEF, THAT THE PLAT CORRECTLY REPRESENTS SAID SURVEY, THAT ALL MONUMENTS FOUND AND ESTABLISHED ARE OF PERMANENT QUALITY AND OCCUPY THE POSITIONS SHOWN THEREON AND THAT THE MONUMENTS ARE SUFFICIENT TO ENABLE THE SURVEY TO BE RETRACED. MADE FOR THE DEPARTMENT OF TRANSPORTATION, STATE OF ILLINOIS.

DATED AT LAKE VILLA, ILLINOIS THIS ____ DAY OF ____ 20__ A.D.

0 30' 60'

SCALE: 1"=30'

ILLINOIS PROFESSIONAL LAND SURVEYOR NO. 35-2797
LICENSE EXPIRATION DATE: NOVEMBER 30, 2024
THIS PROFESSIONAL SERVICE CONFORMS TO THE CURRENT ILLINOIS MINIMUM STANDARDS FOR A BOUNDARY SURVEY.
All dimensions are measured unless otherwise specified.
Areas shown on this plat are ground.
All measured and computed distances are grid not ground.
To obtain ground distances, divide grid distances shown by the combined factor of 0.9999373150.

PROJECT COORDINATES Illinois Coordinate System NAD 83(2011) East Zone			
STATION	OFFSET	NORTH	EAST
95+66.45	91.21' Lt.	1,980,697.309	983,825.880
95+68.01	41.24' Lt.	1,980,696.728	983,775.886
96+14.04	81.81' Rt.	1,980,652.761	983,652.056
96+38.58	81.50' Rt.	1,980,628.041	983,652.017
96+38.63	86.50' Rt.	1,980,628.048	983,647.017
96+98.81	111.03' Rt.	1,980,567.607	983,621.857
96+98.88	85.96' Rt.	1,980,567.341	983,646.921
97+37.82	65.79' Rt.	1,980,528.017	983,666.859

JORGENSEN & ASSOCIATES, INC.
120 PARK AVENUE
LAKE VILLA, ILLINOIS 60046
(847) 356-3371

PLAT OF HIGHWAYS
STATE OF ILLINOIS
DEPARTMENT OF TRANSPORTATION
RANDALL ROAD
LIMITS: RANDALL ROAD AT ILLINOIS ROUTE 72
COUNTY: KANE
SECTION: 19-00514-00-WR JOB NO.: R-91-019-23
STATION 95+00 TO STATION 101+00
STATION 195+00 TO STATION 202+00
SCALE: 1"=30' SHEET 5 OF 9

BUREAU OF LAND ACQUISITION
201 WEST CENTER COURT
SCHAUMBURG, ILLINOIS 60196

F.A.P R.T.E.		SECTION	
0336	19-00514-00-WR	TOTAL SHEETS	SHEET NO.
COUNTY	KANE	304	129
CONTRACT NO.			

DOT USE ONLY

REVISION DATE REVISION

PART OF THE NE 1/4 OF SEC. 19 AND PART OF THE NW 1/4 OF SEC. 20, TWP. 42 N., R. 8 E. OF THE 3RD. P.M., IN KANE COUNTY, ILLINOIS.

FRED-WEST DUNDEE SUBDIVISION
Recorded August 9, 2019
as Document No. 2019K035682

LEGEND



SECTION LINE
QUARTER SECTION LINE
QUARTER QUARTER SECTION LINE
PLATTED LOT LINE
PROPERTY (DEED) LINE

APL
APPARENT PROPERTY LINE
EXISTING CENTER LINE
PROPOSED CENTER LINE
EXISTING RIGHT OF WAY LINE
PROPOSED RIGHT OF WAY LINE
EXISTING EASEMENT
PROPOSED EASEMENT
EXISTING ACCESS CONTROL LINE
PROPOSED ACCESS CONTROL LINE
MEASURED DIMENSION
COMPUTED DIMENSION
RECORD DIMENSION

EXISTING BUILDING

Bearings and Coordinates are referenced to the Illinois Coordinate System NAD 83(2011) East Zone.

- IRON PIPE OR ROD FOUND ⊕ "MAG" NAIL SET
+ CUT CROSS FOUND OR SET ● 5/8" REBAR SET
■ STAKING OF PROPOSED RIGHT OF WAY. SET DIVISION OF HIGHWAYS SURVEY MARKER TO MONUMENT THE POSITION SHOWN, IDENTIFIED BY INSCRIPTION DATA AND SURVEYORS REGISTRATION NUMBER.
■ M STAKING OF PROPOSED RIGHT OF WAY IN CULTIVATED AREAS. BURIED 5/8 INCH METAL ROD 20 INCHES BELOW GROUND TO MARK FUTURE SURVEY MARKER POSITION IDENTIFIED BY COLORED PLASTIC CAP BEARING SURVEYORS REGISTRATION NUMBER.
● PERMANENT SURVEY MARKER, I.D.O.T STD 667101-02 (TO BE SET BY OTHERS)
□ RIGHT OF WAY STAKING PROPOSED TO BE SET.

STATE OF ILLINOIS }
COUNTY OF LAKE }SS

THIS IS TO CERTIFY THAT WE, JORGENSEN & ASSOCIATES, INC., AN ILLINOIS PROFESSIONAL DESIGN FIRM LAND SURVEYING CORPORATION, NUMBER 184-2771, HAVE SURVEYED THE PLAT OF HIGHWAYS SHOWN HEREON BETWEEN SECTION 19, TOWNSHIP 42N., RANGE 8E. AND SECTION 20, TOWNSHIP 42N., RANGE 8E., OF THE THIRD PRINCIPAL MERIDIAN, KANE COUNTY, THAT THE SURVEY IS TRUE AND COMPLETE AS SHOWN TO THE BEST OF MY KNOWLEDGE AND BELIEF, THAT THE PLAT CORRECTLY REPRESENTS SAID SURVEY, THAT ALL MONUMENTS FOUND AND ESTABLISHED ARE OF PERMANENT QUALITY AND OCCUPY THE POSITIONS SHOWN THEREON AND THAT THE MONUMENTS ARE SUFFICIENT TO ENABLE THE SURVEY TO BE RETRACED. MADE FOR THE DEPARTMENT OF TRANSPORTATION, STATE OF ILLINOIS.

DATED AT LAKE VILLA, ILLINOIS THIS ____ DAY OF ____ 20__ A.D.

ILLINOIS PROFESSIONAL LAND SURVEYOR NO. 35-2797
LICENSE EXPIRATION DATE: NOVEMBER 30, 2024

THIS PROFESSIONAL SERVICE CONFORMS TO THE CURRENT ILLINOIS MINIMUM STANDARDS FOR A BOUNDARY SURVEY.

All dimensions are measured unless otherwise specified.
Areas shown on this plat are ground.
All measured and computed distances are grid not ground.
To obtain ground distances, divide grid distances shown by the combined factor of 0.9999373150.

PROJECT COORDINATES Illinois Coordinate System NAD 83(2011) East Zone			
STATION	OFFSET	NORTH	EAST
89+80.00	80.16' Rt.	1,981,288.524	983,676.552
89+80.49	100.15' Rt.	1,981,288.880	983,656.556
89+80.61	105.15' Rt.	1,981,288.970	983,651.556
91+42.93	71.84' Lt.	1,981,119.280	983,821.490
92+44.83	12.20' Rt.	1,981,021.038	983,733.195
92+47.32	72.15' Rt.	1,981,021.094	983,673.199
92+60.85	71.59' Rt.	1,981,007.560	983,673.186
93+38.55	70.62' Rt.	1,980,929.699	983,670.886
93+38.62	75.62' Rt.	1,980,929.830	983,665.888

JORGENSEN & ASSOCIATES, INC.
120 PARK AVENUE
LAKE VILLA, ILLINOIS 60046
(847) 356-3371

PLAT OF HIGHWAYS
STATE OF ILLINOIS
DEPARTMENT OF TRANSPORTATION
RANDALL ROAD

LIMITS: RANDALL ROAD AT ILLINOIS ROUTE 72
COUNTY: KANE
SECTION: 19-00514-00-WR JOB NO.: R-91-019-23
STATION 89+00 TO STATION 97+00
SCALE: 1"=30' SHEET 6 OF 9


BUREAU OF LAND ACQUISITION
201 WEST CENTER COURT
SCHAUMBURG, ILLINOIS 60196

SECOND ADDITION TO COUNTRY
VIEW HIGHLANDS SUBDIVISION
Recorded June 9, 1959
as Document No. 891700

Parcel	Document No.	Date Recorded
1PK0005	94K091088	December 19, 1994
1PK0005	2010K077141	November 15, 2010
----	891700	June 9, 1959
----	918296	April 27, 1960
----	1999K040977	April 22, 1999
----	2019K035682	August 9, 2019

Existing & Proposed
Pavement
Randall Road
Curve #2


P.I. = Sta. 95+41.56
Δ = 2'22.37"
R = 11231.37'
T = 233.01'
L = 465.96'
P.C. = Sta. 93+08.54
P.T. = Sta. 97+74.50

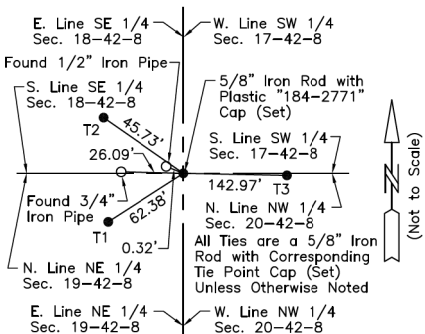

M-6
"Monument Record"

Northwest Corner of Section 20-42-8
N.1,982,916.445-E.983,735.490
Recorded June 9, 2010
Document No. 2010K036886

N. Line of Warranty Deed
Rec. March 20, 2017 as
Doc. 2017K013971

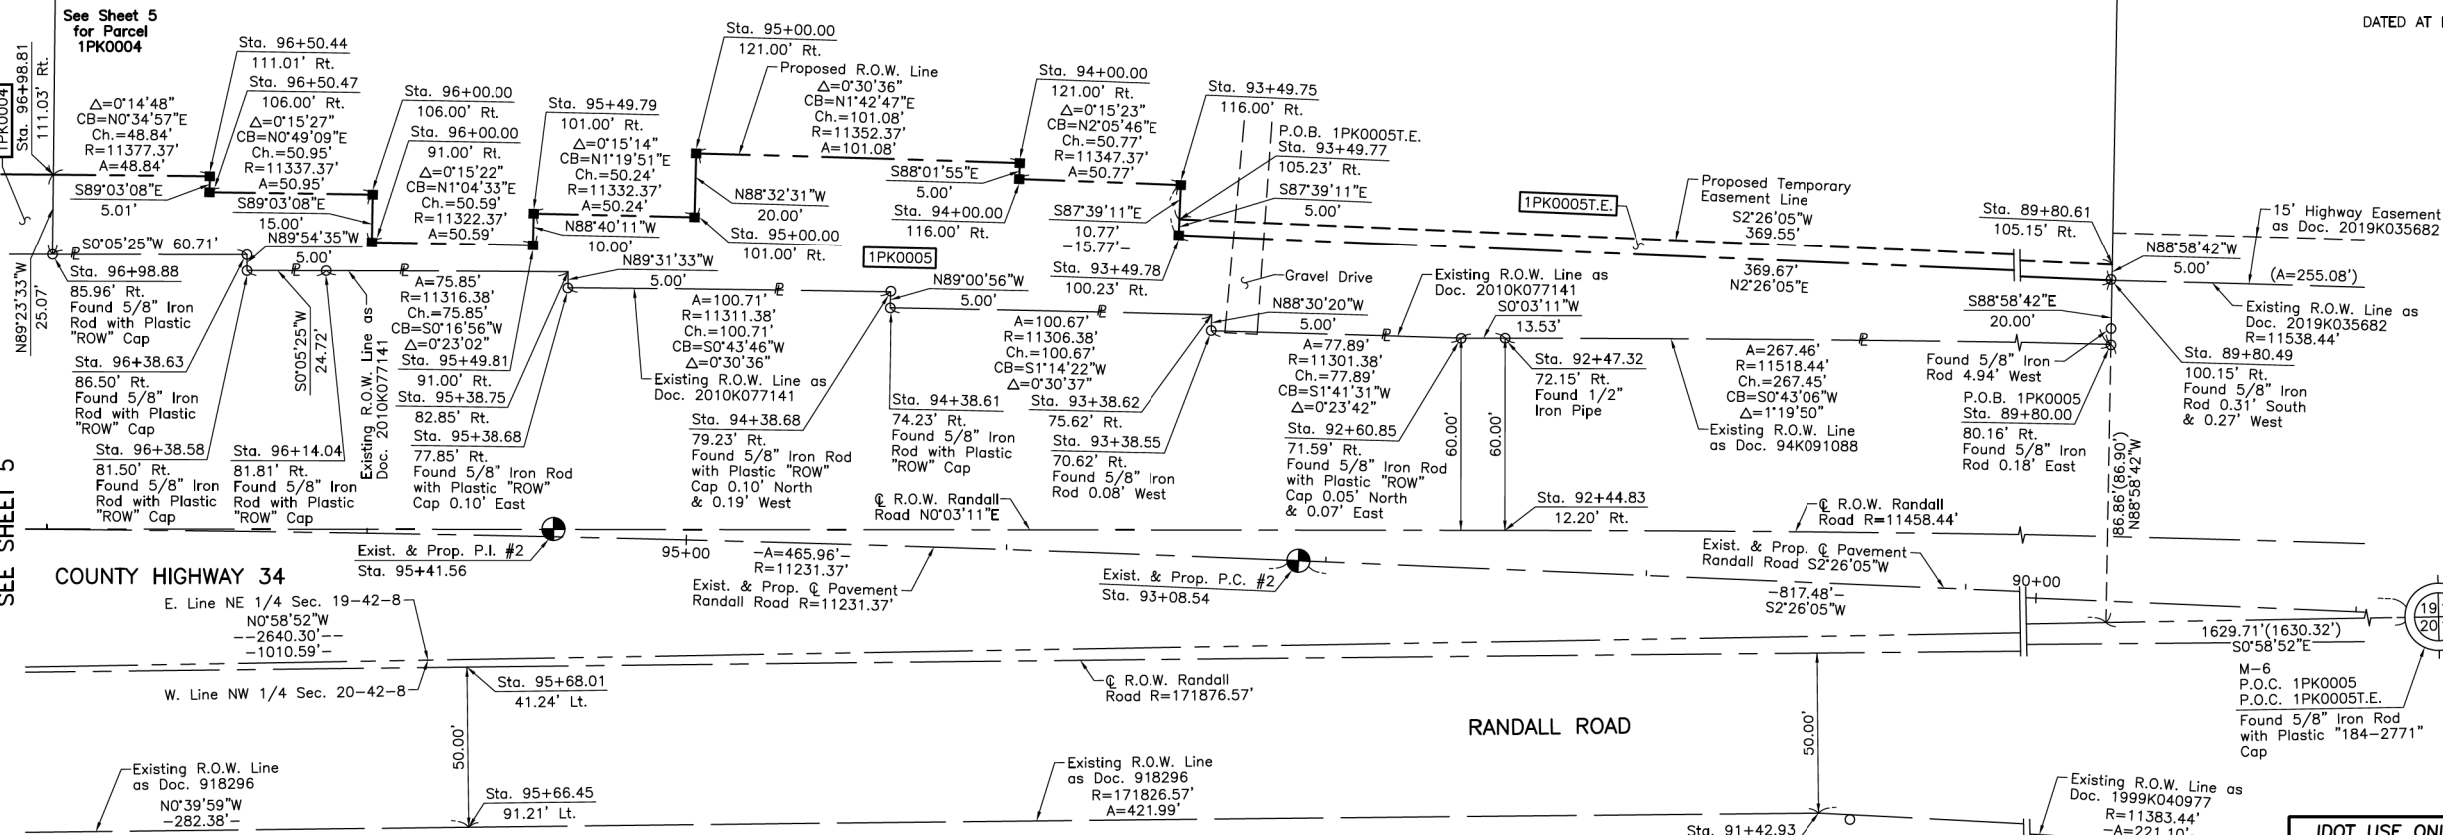


PARCEL NUMBER	TOTAL HOLDINGS ACRES	PART TAKEN ACRES	AREA IN EXISTING R.O.W. ACRES	REMAINDER AREA ACRES	EASEMENT AREA ACRES	EASEMENT PURPOSE	PERMANENT INDEX NUMBER
1PK0005 1PK0005T.E.	6.020	0.450	N/A	5.570	0.042	Grading	03-19-200-004

F.A.P. RTE.	SECTION	COUNTY	TOTAL SHEETS	SHEET NO.
0336	19-00514-00-WR	KANE	304	130
CONTRACT NO.				

REVISION DATE

REVISION

PART OF THE EAST 1/2 OF SEC. 19 AND PART OF THE WEST 1/2 OF SEC. 20, TWP. 42 N., R. 8 E. OF THE 3RD. P.M., IN KANE COUNTY, ILLINOIS.

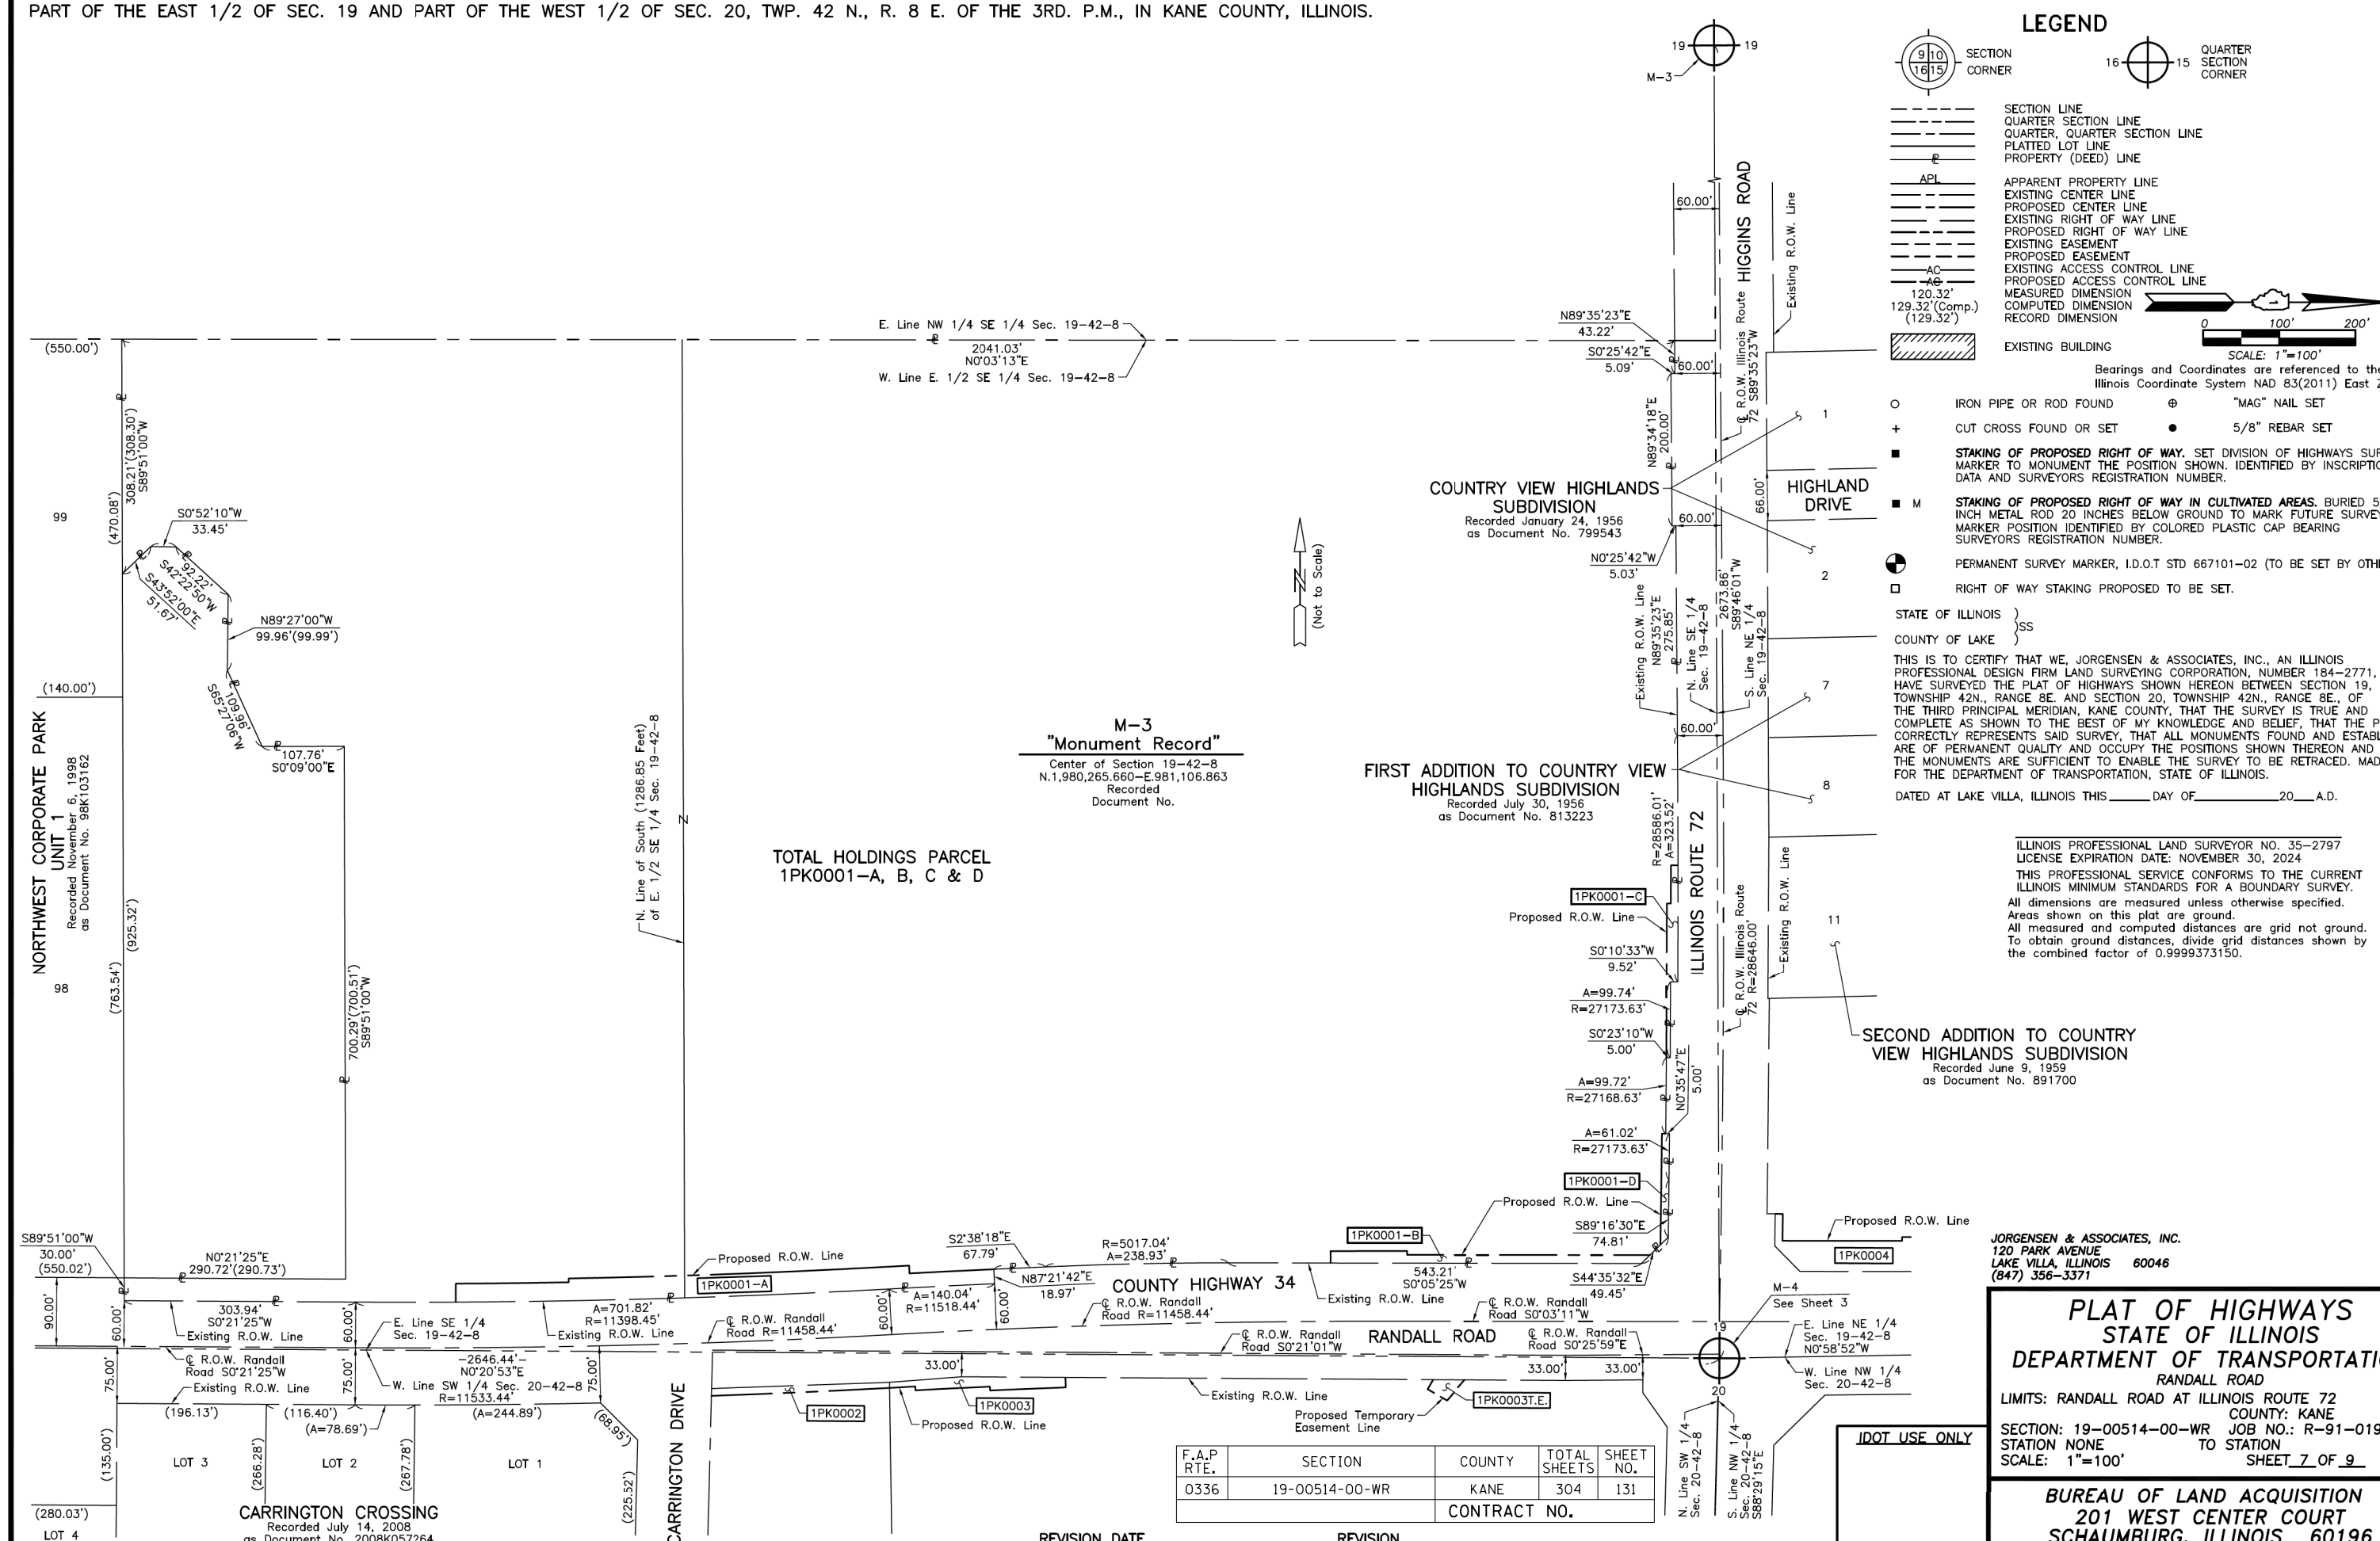

LEGEND

- SECTION LINE
- QUARTER SECTION LINE
- QUARTER, QUARTER SECTION LINE
- PLATTED LOT LINE
- PROPERTY (DEED) LINE
- APL APPARENT PROPERTY LINE
- EXISTING CENTER LINE
- PROPOSED CENTER LINE
- EXISTING RIGHT OF WAY LINE
- PROPOSED RIGHT OF WAY LINE
- EXISTING EASEMENT
- PROPOSED EASEMENT
- EXISTING ACCESS CONTROL LINE
- PROPOSED ACCESS CONTROL LINE
- MEASURED DIMENSION
- COMPUTED DIMENSION
- RECORD DIMENSION
- EXISTING BUILDING
- IRON PIPE OR ROD FOUND
- CUT CROSS FOUND OR SET
- STAKING OF PROPOSED RIGHT OF WAY. SET DIVISION OF HIGHWAYS SURVEY MARKER TO MONUMENT THE POSITION SHOWN, IDENTIFIED BY INSCRIPTION DATA AND SURVEYORS REGISTRATION NUMBER.
- STAKING OF PROPOSED RIGHT OF WAY IN CULTIVATED AREAS. BURIED 5/8 INCH METAL ROD 20 INCHES BELOW GROUND TO MARK FUTURE SURVEY MARKER POSITION IDENTIFIED BY COLORED PLASTIC CAP BEARING SURVEYORS REGISTRATION NUMBER.
- PERMANENT SURVEY MARKER, I.D.O.T STD 667101-02 (TO BE SET BY OTHERS)
- RIGHT OF WAY STAKING PROPOSED TO BE SET.

STATE OF ILLINOIS }
COUNTY OF LAKE }
THIS IS TO CERTIFY THAT WE, JORGENSEN & ASSOCIATES, INC., AN ILLINOIS PROFESSIONAL DESIGN FIRM LAND SURVEYING CORPORATION, NUMBER 184-2771, HAVE SURVEYED THE PLAT OF HIGHWAYS SHOWN HEREON BETWEEN SECTION 19, TOWNSHIP 42N., RANGE 8E. AND SECTION 20, TOWNSHIP 42N., RANGE 8E., OF THE THIRD PRINCIPAL MERIDIAN, KANE COUNTY, THAT THE SURVEY IS TRUE AND COMPLETE AS SHOWN TO THE BEST OF MY KNOWLEDGE AND BELIEF, THAT THE PLAT CORRECTLY REPRESENTS SAID SURVEY, THAT ALL MONUMENTS FOUND AND ESTABLISHED ARE OF PERMANENT QUALITY AND OCCUPY THE POSITIONS SHOWN THEREON AND THAT THE MONUMENTS ARE SUFFICIENT TO ENABLE THE SURVEY TO BE RETRACED. MADE FOR THE DEPARTMENT OF TRANSPORTATION, STATE OF ILLINOIS.
DATED AT LAKE VILLA, ILLINOIS THIS ____ DAY OF ____ 20__ A.D.

ILLINOIS PROFESSIONAL LAND SURVEYOR NO. 35-2797
LICENSE EXPIRATION DATE: NOVEMBER 30, 2024
THIS PROFESSIONAL SERVICE CONFORMS TO THE CURRENT ILLINOIS MINIMUM STANDARDS FOR A BOUNDARY SURVEY.
All dimensions are measured unless otherwise specified.
Areas shown on this plat are ground.
All measured and computed distances are grid not ground.
To obtain ground distances, divide grid distances shown by the combined factor of 0.9999373150.

SECOND ADDITION TO COUNTRY VIEW HIGHLANDS SUBDIVISION
Recorded June 9, 1959
as Document No. 891700


JORGENSEN & ASSOCIATES, INC.
120 PARK AVENUE
LAKE VILLA, ILLINOIS 60046
(847) 356-3371

PLAT OF HIGHWAYS
STATE OF ILLINOIS
DEPARTMENT OF TRANSPORTATION
RANDALL ROAD
LIMITS: RANDALL ROAD AT ILLINOIS ROUTE 72
COUNTY: KANE
SECTION: 19-00514-00-WR JOB NO.: R-91-019-23
STATION NONE TO STATION
SCALE: 1"=100' SHEET 7 OF 9
BUREAU OF LAND ACQUISITION
201 WEST CENTER COURT
SCHAUMBURG, ILLINOIS 60196

F.A.P RTE.	SECTION	COUNTY	TOTAL SHEETS	SHEET NO.
0336	19-00514-00-WR	KANE	304	131
CONTRACT NO.				

M-3
"Monument Record"
Center of Section 19-42-8
N.1,980,265.660-E.981,106.863
Recorded
Document No.

PART OF THE SE 1/4 OF SEC. 19 AND PART OF THE WEST 1/2 OF SEC. 20, TWP. 42 N., R. 8 E. OF THE 3RD. P.M., IN KANE COUNTY, ILLINOIS.

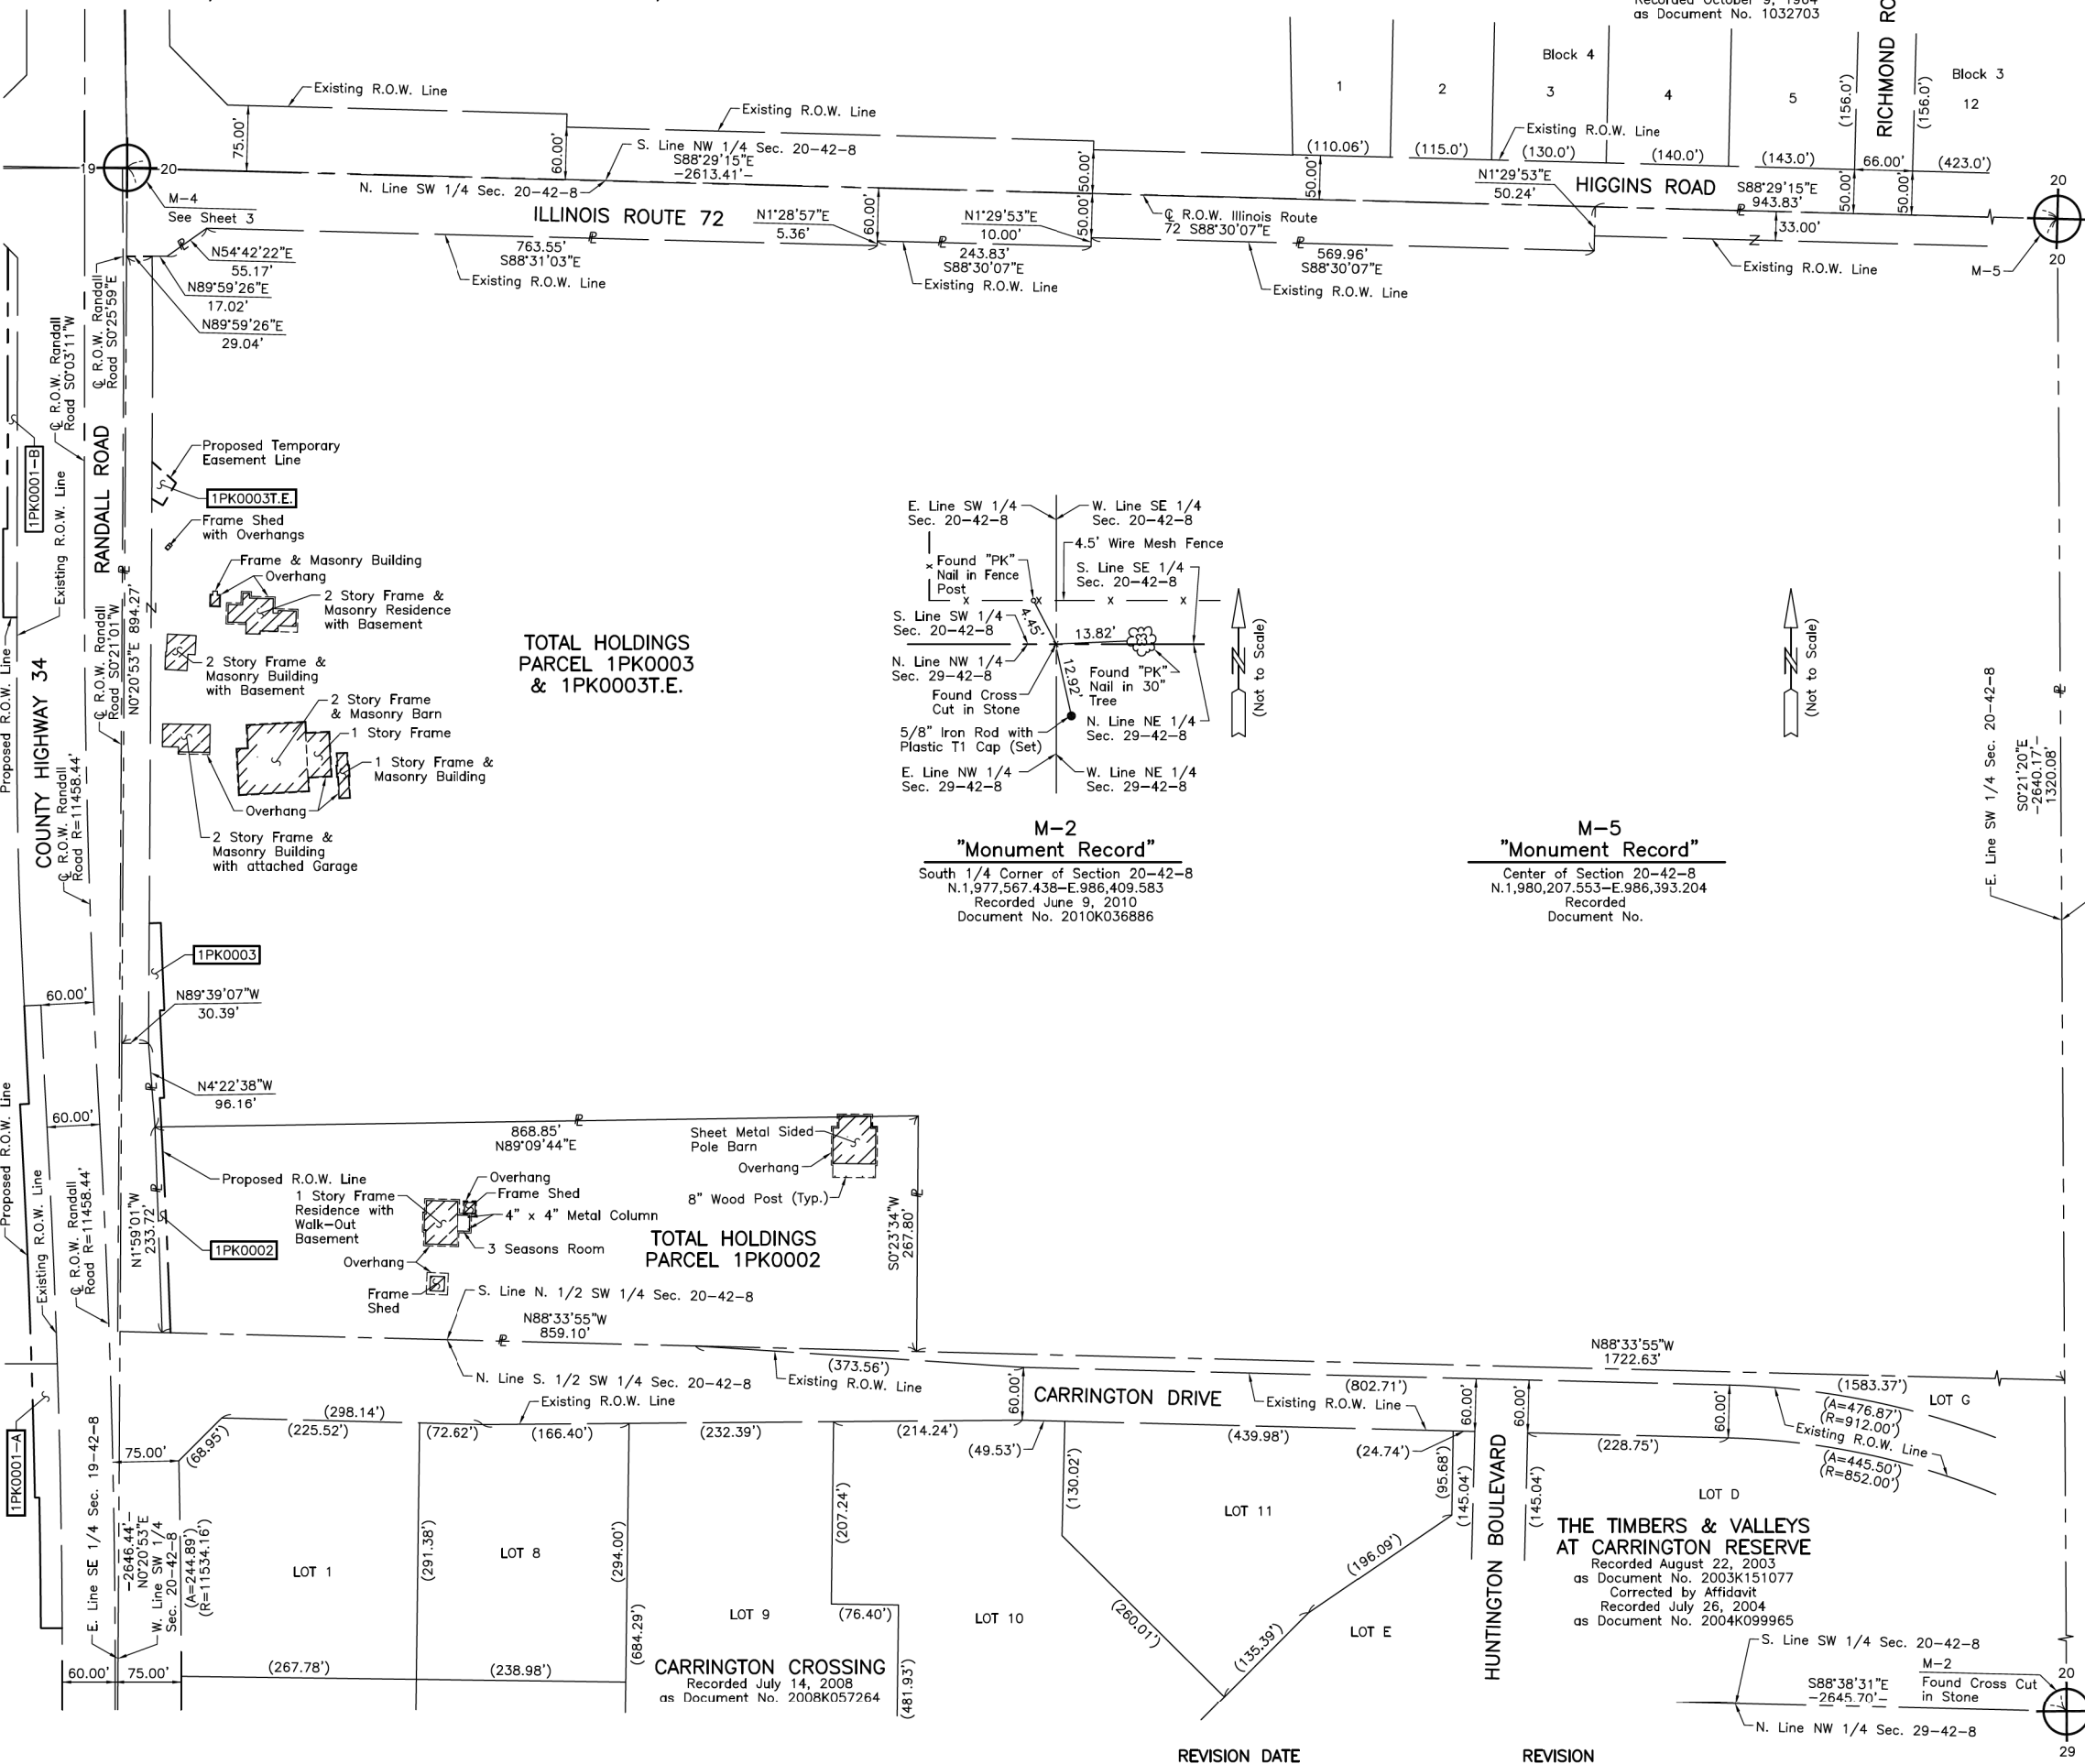

LEGEND

SECTION CORNER: 9 10 16 15

QUARTER SECTION CORNER: 16 15

SECTION LINE
QUARTER SECTION LINE
QUARTER, QUARTER SECTION LINE
PLATTED LOT LINE
PROPERTY (DEED) LINE

APL
APPARENT PROPERTY LINE
EXISTING CENTER LINE
PROPOSED CENTER LINE
EXISTING RIGHT OF WAY LINE
PROPOSED RIGHT OF WAY LINE
EXISTING EASEMENT
PROPOSED EASEMENT
EXISTING ACCESS CONTROL LINE
PROPOSED ACCESS CONTROL LINE
MEASURED DIMENSION
COMPUTED DIMENSION
RECORD DIMENSION

EXISTING BUILDING

Bearings and Coordinates are referenced to the Illinois Coordinate System NAD 83(2011) East Zone.

0 100' 200'
SCALE: 1"=100'

- O IRON PIPE OR ROD FOUND ⊕ "MAG" NAIL SET
+ CUT CROSS FOUND OR SET • 5/8" REBAR SET
- **STAKING OF PROPOSED RIGHT OF WAY.** SET DIVISION OF HIGHWAYS SURVEY MARKER TO MONUMENT THE POSITION SHOWN, IDENTIFIED BY INSCRIPTION DATA AND SURVEYORS REGISTRATION NUMBER.
- M **STAKING OF PROPOSED RIGHT OF WAY IN CULTIVATED AREAS.** BURIED 5/8 INCH METAL ROD 20 INCHES BELOW GROUND TO MARK FUTURE SURVEY MARKER POSITION IDENTIFIED BY COLORED PLASTIC CAP BEARING SURVEYORS REGISTRATION NUMBER.
- PERMANENT SURVEY MARKER, I.D.O.T STD 667101-02 (TO BE SET BY OTHERS)
- RIGHT OF WAY STAKING PROPOSED TO BE SET.

STATE OF ILLINOIS }
COUNTY OF LAKE }SS

THIS IS TO CERTIFY THAT WE, JORGENSEN & ASSOCIATES, INC., AN ILLINOIS PROFESSIONAL DESIGN FIRM LAND SURVEYING CORPORATION, NUMBER 184-2771, HAVE SURVEYED THE PLAT OF HIGHWAYS SHOWN HEREON BETWEEN SECTION 19, TOWNSHIP 42N., RANGE 8E. AND SECTION 20, TOWNSHIP 42N., RANGE 8E., OF THE THIRD PRINCIPAL MERIDIAN, KANE COUNTY, THAT THE SURVEY IS TRUE AND COMPLETE AS SHOWN TO THE BEST OF MY KNOWLEDGE AND BELIEF, THAT THE PLAT CORRECTLY REPRESENTS SAID SURVEY, THAT ALL MONUMENTS FOUND AND ESTABLISHED ARE OF PERMANENT QUALITY AND OCCUPY THE POSITIONS SHOWN THEREON AND THAT THE MONUMENTS ARE SUFFICIENT TO ENABLE THE SURVEY TO BE RETRACED. MADE FOR THE DEPARTMENT OF TRANSPORTATION, STATE OF ILLINOIS.

DATED AT LAKE VILLA, ILLINOIS THIS ____ DAY OF ____ 20__ A.D.

ILLINOIS PROFESSIONAL LAND SURVEYOR NO. 35-2797
LICENSE EXPIRATION DATE: NOVEMBER 30, 2024

THIS PROFESSIONAL SERVICE CONFORMS TO THE CURRENT ILLINOIS MINIMUM STANDARDS FOR A BOUNDARY SURVEY.

All dimensions are measured unless otherwise specified.
Areas shown on this plat are ground.
All measured and computed distances are grid not ground.
To obtain ground distances, divide grid distances shown by the combined factor of 0.9999373150.

F.A.P. RTE.	SECTION	COUNTY	TOTAL SHEETS	SHEET NO.
0336	19-00514-00-WR	KANE	304	132
CONTRACT NO.				

JORGENSEN & ASSOCIATES, INC.
120 PARK AVENUE
LAKE VILLA, ILLINOIS 60046
(847) 356-3371

PLAT OF HIGHWAYS
STATE OF ILLINOIS
DEPARTMENT OF TRANSPORTATION
RANDALL ROAD

LIMITS: RANDALL ROAD AT ILLINOIS ROUTE 72
COUNTY: KANE

SECTION: 19-00514-00-WR JOB NO.: R-91-019-23
STATION NONE TO STATION
SCALE: 1"=100' SHEET 8 OF 9

BUREAU OF LAND ACQUISITION
201 WEST CENTER COURT
SCHAUMBURG, ILLINOIS 60196

LEGEND

SECTION CORNER

QUARTER SECTION CORNER

SECTION LINE

QUARTER SECTION LINE

PLATTED LOT LINE

PROPERTY (DEED) LINE

APPARENT PROPERTY LINE

EXISTING CENTER LINE

PROPOSED CENTER LINE

EXISTING RIGHT OF WAY LINE

PROPOSED RIGHT OF WAY LINE

EXISTING EASEMENT

PROPOSED EASEMENT

EXISTING ACCESS CONTROL LINE

PROPOSED ACCESS CONTROL LINE

MEASURED DIMENSION

COMPUTED DIMENSION

RECORD DIMENSION

EXISTING BUILDING

N

0 200' 400'
SCALE: 1"=200'

ILLINOIS PROFESSIONAL LAND SURVEYOR NO. 35-2797
 LICENSE EXPIRATION DATE: NOVEMBER 30, 2024
 THIS PROFESSIONAL SERVICE CONFORMS TO THE CURRENT
 ILLINOIS MINIMUM STANDARDS FOR A BOUNDARY SURVEY.
 All dimensions are measured unless otherwise specified.
 Areas shown on this plat are ground.
 All measured and computed distances are grid not ground.
 To obtain ground distances, divide grid distances shown by
 the combined factor of 0.9999373150.

JORGENSEN & ASSOCIATES, INC.
120 PARK AVENUE
LAKE VILLA, ILLINOIS 60046
(847) 356-3371

**PLAT OF HIGHWAYS
STATE OF ILLINOIS
DEPARTMENT OF TRANSPORTATION
RANDALL ROAD**

LIMITS: RANDALL ROAD AT ILLINOIS ROUTE 72
COUNTY: KANE

SECTION: 19-00514-00-WR JOB NO.: R-91-019-23
STATION 84+91.07 TO STATION 117+82.42
STATION 173+74.28 TO STATION 229+83.77
SCALE: 1"=200' SHEET 9 OF 9

**BUREAU OF LAND ACQUISITION
201 WEST CENTER COURT
SCHAUMBURG, ILLINOIS 60196**

Existing & Proposed Pavement Curve #2

P.I.	= Sta. 95+41.56
Δ	= 2°22'37"
R	= 11231.37'
T	= 233.01'
L	= 465.96'
E	= 2.42'
P.C.	= Sta. 93+08.54
P.T.	= Sta. 97+74.50

Existing & Proposed Pavement Curve #3

P.I.	= Sta. 107+54.54
Δ	= 3°13'27"
R	= 11459.16'
T	= 322.49'
L	= 644.81'
E	= 4.54'
P.C.	= Sta. 104+32.05
P.R.C.	= Sta. 110+76.86

Existing & Proposed Pavement Curve #4

P.I.	= Sta. 114+29.75
Δ	= 3°31'40"
R	= 11459.16'
T	= 352.89'
L	= 705.56'
E	= 5.43'
P.R.C.	= Sta. 110+76.86
P.T.	= Sta. 117+82.42

Existing & Proposed Pavement Curve #1

P.I.	= Sta. 197+06.93
Δ	= 1°54'30"
R	= 27243.63'
T	= 453.74'
L	= 907.40'
E	= 3.78'
P.C.	= Sta. 192+53.19
P.T.	= Sta. 201+60.59


PROJECT COORDINATES
Illinois Coordinate System NAD 83(2011) East Zone

STATION	NORTH	EAST
84+91.07	1,981,773.603	983,777.408
90+00.00	1,981,265.131	983,755.788
93+08.54	1,980,956.866	983,742.682
95+41.56	1,980,724.063	983,732.783
97+74.50	1,980,491.050	983,732.549
99+88.89	1,980,276.661	983,732.334
104+32.05	1,979,833.503	983,731.888
107+54.54	1,979,511.014	983,731.564
110+76.86	1,979,189.017	983,749.378
113+00.00	1,978,966.111	983,759.533
114+29.75	1,978,836.664	983,768.870
117+82.42	1,978,483.780	983,766.645
173+74.28	1,980,268.097	981,106.852
189+50.00	1,980,279.377	982,682.532
192+53.19	1,980,281.548	982,985.714
197+06.93	1,980,284.796	983,439.442
199+99.85	1,980,276.661	983,732.334
201+60.59	1,980,272.933	983,893.028
211+00.00	1,980,248.371	984,832.120
229+83.77	1,980,199.120	986,715.243

PROJECT COORDINATES		
Illinois Coordinate System NAD 83(2011) East Zone		
STATION	NORTH	EAST
84+91.07	1,981,773.603	983,777.408
90+00.00	1,981,265.131	983,755.788
93+08.54	1,980,956.866	983,742.682
95+41.56	1,980,724.063	983,732.783
97+74.50	1,980,491.050	983,732.549
99+88.89	1,980,276.661	983,732.334
104+32.05	1,979,833.503	983,731.888
107+54.54	1,979,511.014	983,731.564
110+76.86	1,979,189.017	983,749.378
113+00.00	1,978,966.111	983,759.533
114+29.75	1,978,836.664	983,768.870
117+82.42	1,978,483.780	983,766.645
173+74.28	1,980,268.097	981,106.852
189+50.00	1,980,279.377	982,682.532
192+53.19	1,980,281.548	982,985.714
197+06.93	1,980,284.796	983,439.442
199+99.85	1,980,276.661	983,732.334
201+60.59	1,980,272.933	983,893.028
211+00.00	1,980,248.371	984,832.120
229+83.77	1,980,199.120	986,715.243

F.A.P RTE.	SECTION	COUNTY	TOTAL SHEETS	SHEE NO.
0336	19-00514-00-WR	KANE	304	133
		CONTRACT NO.		

REVISION	DATE	REVISION
----------	------	----------

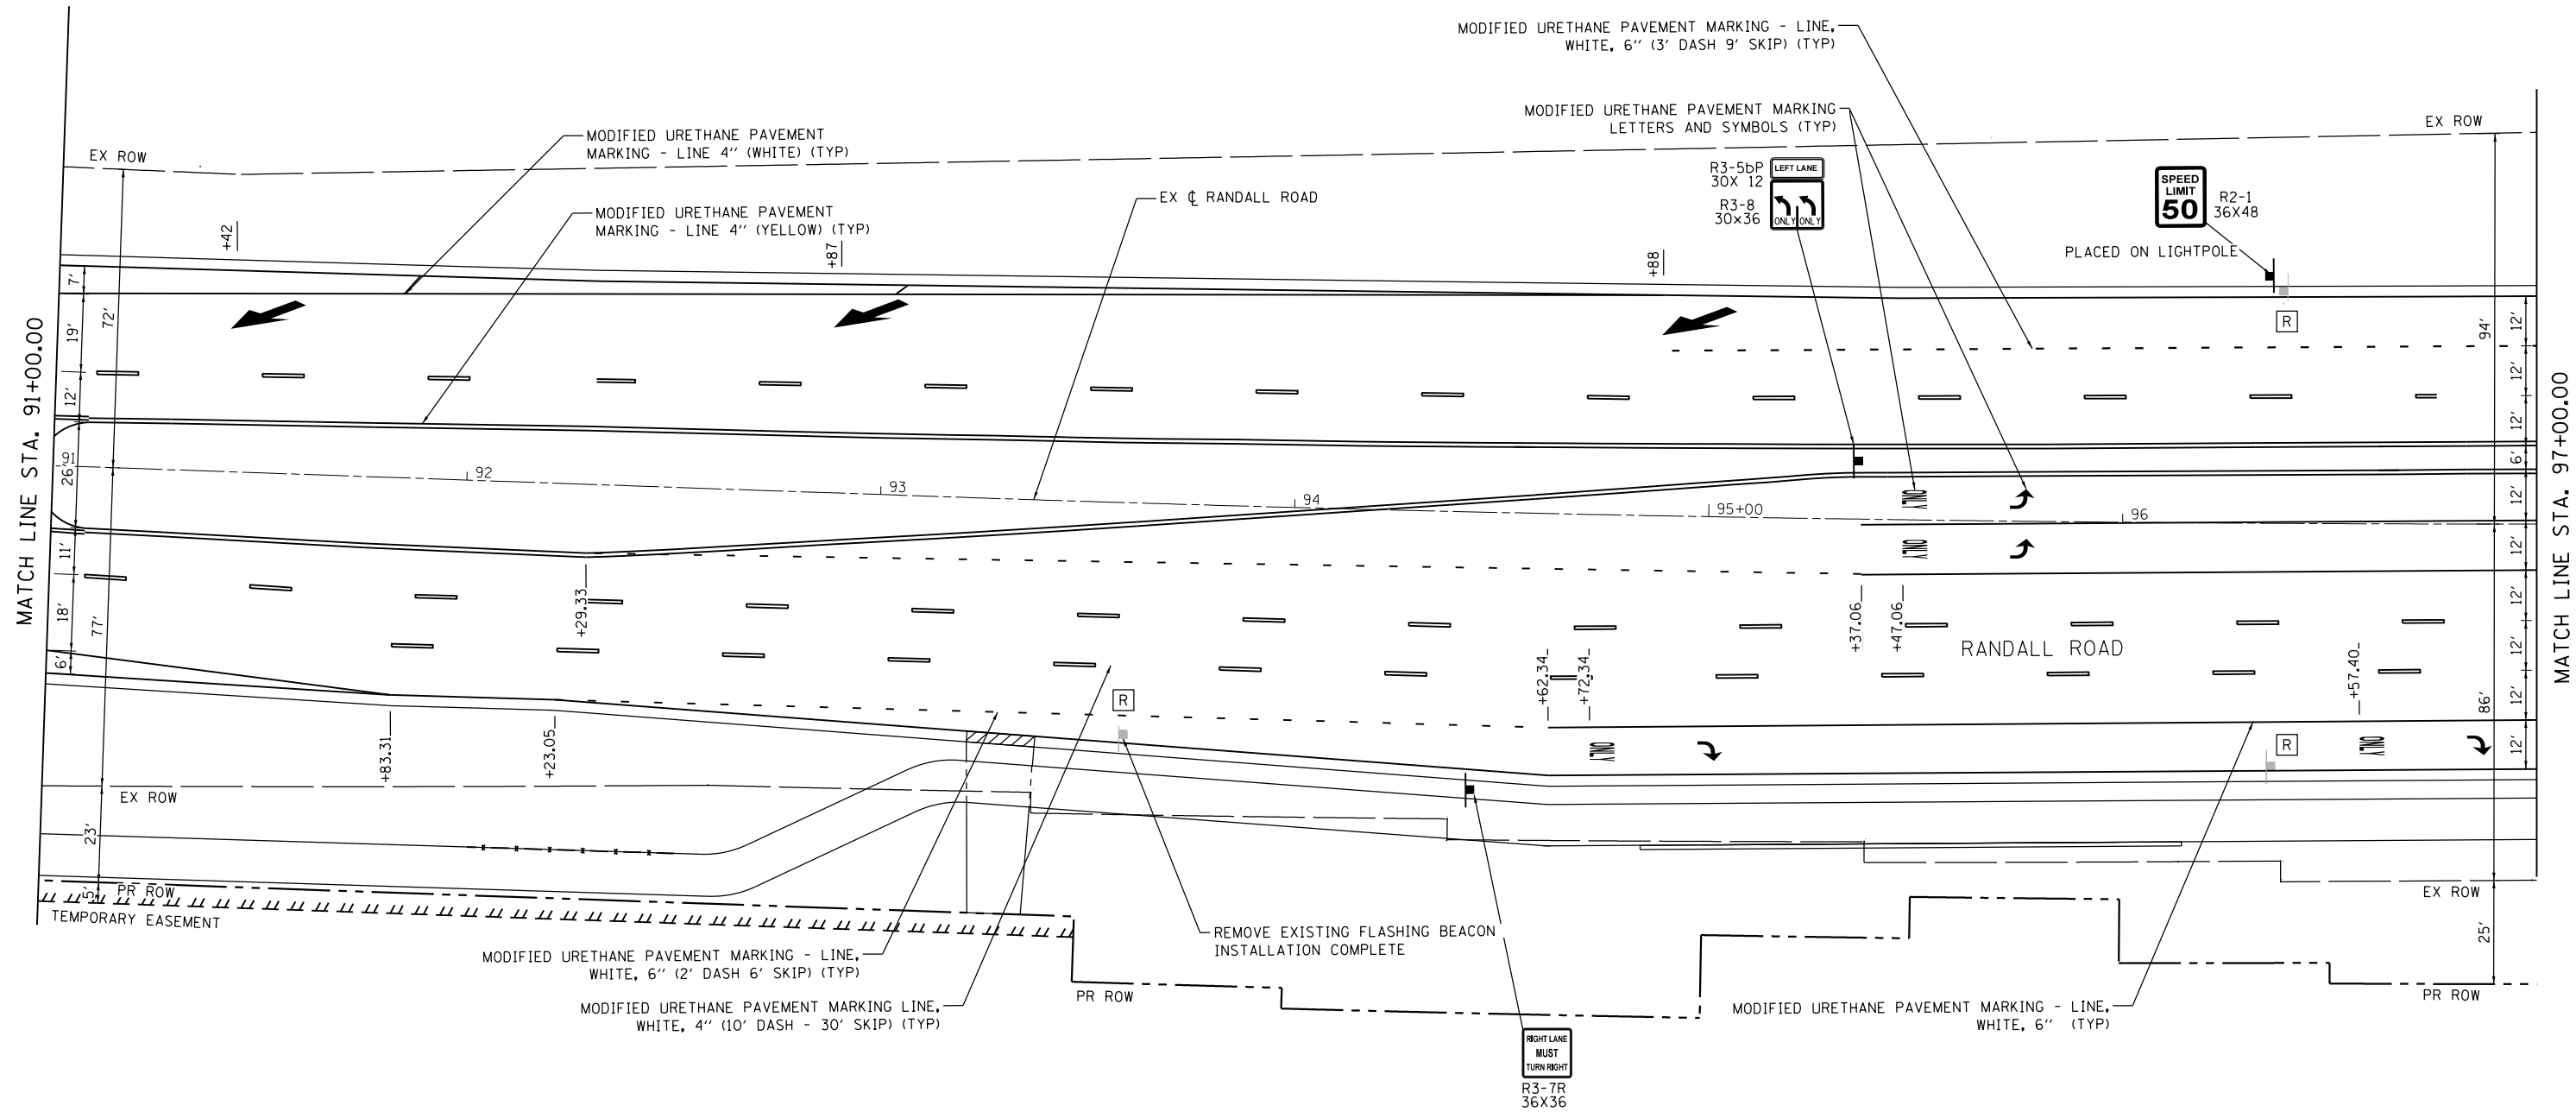

MODEL D:\dell\B\BLA\488 Randall at Higgins Phase II Engineering\CADD_Sheets\013_PMK and Signing Plans\19-00514-00-WR_PMK_002.dgn
FILE NAME: 19-00514-00-WR_PMK and Signing Plans\19-00514-00-WR_PMK_002.dgn





USER NAME : cesario	DESIGNED - TN	REVISED -
	DRAWN - TN	REVISED -
PLOT SCALE = 40.0000' / in.	CHECKED - GJE	REVISED -
PLOT DATE = 6/19/2025	DATE - 02/15/2025	REVISED -

STATE OF ILLINOIS
DEPARTMENT OF TRANSPORTATION

RANDALL ROAD AT IL ROUTE 72 (HIGGINS ROAD) PAVEMENT MARKING AND SIGNING PLAN			
SCALE: 1"=20'	SHEET 2 OF 7 SHEETS	STA. 91+00.00 TO STA. 97+00.00	

F.A.P. RTE.	SECTION	COUNTY	TOTAL SHEETS	SHEET NO.
0336	19-00514-00-WR	KANE	304	135
CONTRACT NO. 61L28				
ILLINOIS FED. AID PROJECT				

 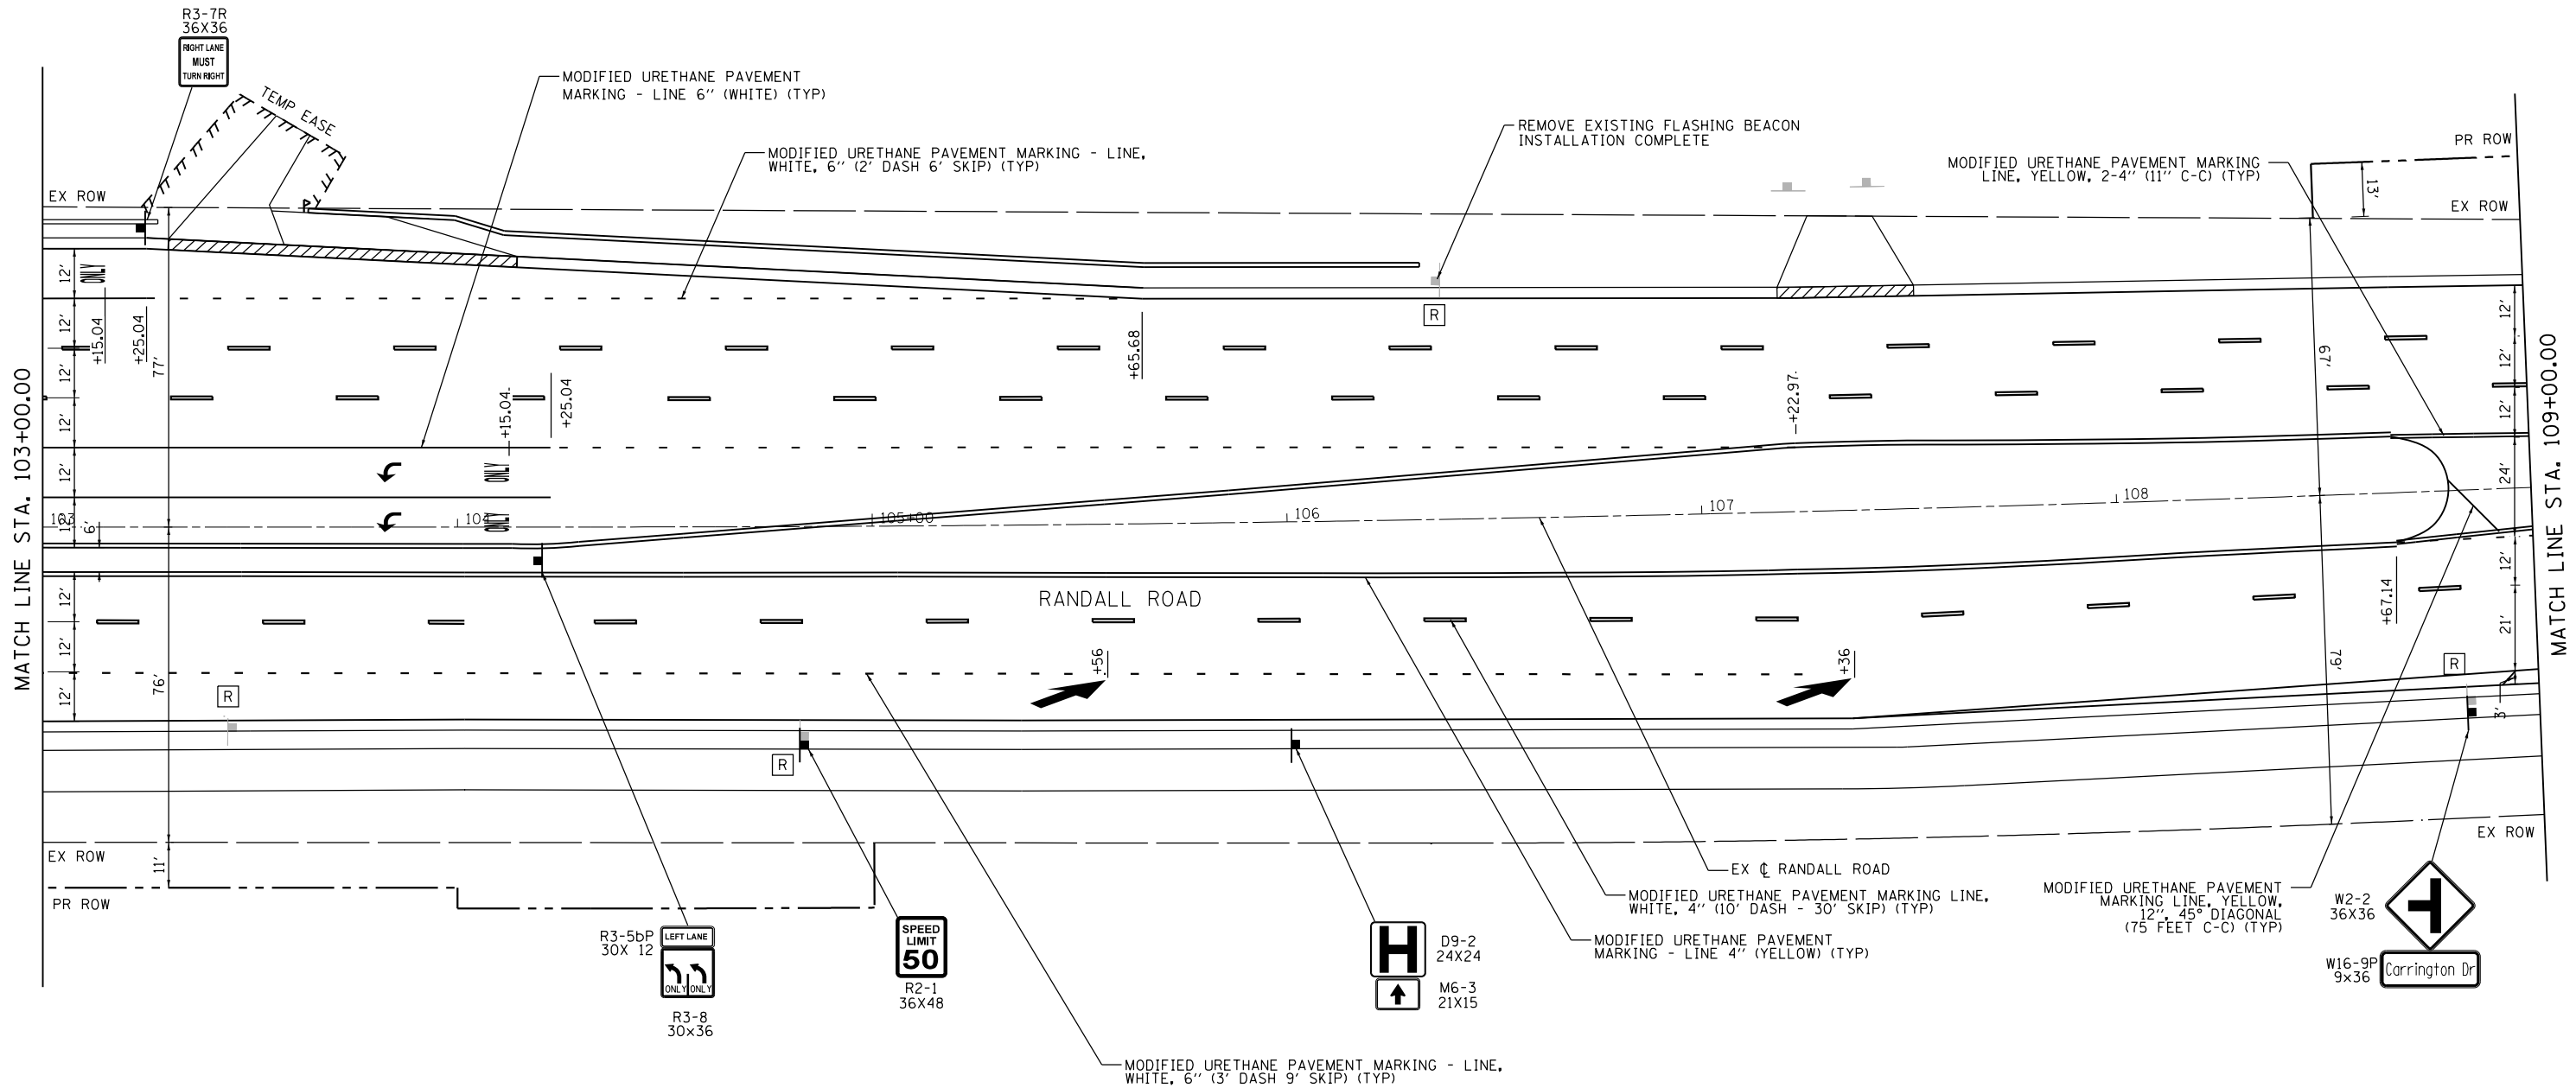

MODEL: D:\bls\11\11-000000\11-000000.dgn
FILE NAME: 11-000000.dgn
PROJECT: 11-000000
SHEET: 11-000000
DATE: 6/19/2025





USER NAME : cesario	DESIGNED - TN	REVISED -
	DRAWN - TN	REVISED -
PLOT SCALE = 40.0000' / in.	CHECKED - GJE	REVISED -
PLOT DATE = 6/19/2025	DATE - 02/15/2025	REVISED -

STATE OF ILLINOIS
DEPARTMENT OF TRANSPORTATION

RANDALL ROAD AT IL ROUTE 72 (HIGGINS ROAD)
PAVEMENT MARKING AND SIGNING PLAN

SCALE: 1"=20' SHEET 4 OF 7 SHEETS STA. 103+00.00 TO STA. 109+00.00

F.A.P. RTE.	SECTION	COUNTY	TOTAL SHEETS	SHEET NO.
0336	19-00514-00-WR	KANE	304	137
CONTRACT NO. 61L28				
ILLINOIS FED. AID PROJECT				

  

RANDALL ROAD AT IL ROUTE 72 (HIGGINS ROAD)
PAVEMENT MARKING AND SIGNING PLAN

SCALE: 1"=20'	SHEET 5 OF 7 SHEETS	STA. 109+00.00 TO STA. 115+00.00
---------------	---------------------	----------------------------------

F.A.P. RTE.	SECTION	COUNTY	TOTAL SHEETS	SHEET NO.
0336	19-00514-00-WR	KANE	304	138
		CONTRACT NO. 61L2		
ILLINOIS		FED. AID PROJECT		

MODEL: Default
FILE NAME: W:\894-088 Randall at Higgins Phase II Engineering\CADD Sheets\013_PMK and Signing Plans\1500054-00-VIR_SIGN_Schedule.dgn

RANDALL ROAD							
STATION	OFFSET	SIGN DESIGNATION	SIZE (L x H) (INCH)		AREA (SF)	SIGN TYPE	TELESCOPING POST LENGTH (FT)
90+15.94	54.60 RT	D3-2 Modified (KDOT SPECIAL)	60	18	7.5	TYPE I	13
94+44.03	68.86 RT	R3-7R	36	36	9	TYPE 2	15
95+35.88	14.12 LT	R3-8	30	36	7.5	TYPE I	15
95+35.88	14.12 LT	R3-5bP	30	12	2.5	TYPE I	13
96+38.54	63.25 LT	R2-1	36	48	12	TYPE 2	LIGHT POLE
98+12.42	63.48 RT	R3-7R	36	36	9.0	TYPE 2	15
98+39.94	69.78 LT	W4-2	48	48	16.0	TYPE 2	16
98+67.56	63.48 RT	M1-I100.2	24	24	4.0	TYPE I	15
		M6-4	21	15	2.2	TYPE I	
98+69.73	16.11 LT	R3-8	30	36	7.5	TYPE I	19
		R4-7	30	24	5.0	TYPE I	
		OM3-L	36	12	3.0	TYPE I	
99+25.28	126.72 RT	M3-4	24	8	1.3	TYPE I	15
		M1-I100.2	24	24	4.0	TYPE I	
99+74.37	104.31 RT	OM3-L	36	12	3.0	TYPE I	19
		R3-8	30	36	7.5	TYPE I	
		R4-7	30	24	5.0	TYPE I	
100+03.96	114.87 LT	OM3-L	36	12	3.0	TYPE I	19
		R3-8	30	36	7.5	TYPE I	
		R4-7	30	24	5.0	TYPE I	
100+54.76	124.50 RT	R3-7R	36	36	9.0	TYPE 2	15
100+60.07	125.95 LT	M3-2	24	8	1.3	TYPE I	15
		M1-I100.2	24	24	4.0	TYPE I	
100+89.43	8.28 RT	OM3-L	36	12	3.0	TYPE I	19
		R3-8	30	24	5.0	TYPE I	
		R4-7	30	36	7.5	TYPE I	
100+97.30	71.97 LT	R3-7R	36	36	9.0	TYPE 2	LIGHT POLE
101+27.09	58.13 RT	W4-2	48	48	16.0	TYPE 2	16
101+65.97	72.06 LT	M1-I100.2	24	24	4.0	TYPE I	15
		M6-4	21	15	2.2	TYPE I	
103+23.63	71.98 LT	R3-7R	36	36	9.0	TYPE 2	15
104+19.37	8.15 RT	R3-8	30	36	7.5	TYPE I	15
104+19.37	8.15 RT	R3-5bP	30	12	2.5	TYPE I	13
104+83.33	52.56 RT	R2-1	36	48	12.0	TYPE 2	16
106+01.29	53.80 RT	D9-2	24	24	4.0	TYPE I	15
		M6-3	21	15	2.2	TYPE I	
108+83.70	53.61 RT	W2-2	36	36	9.0	TYPE 2	19
		W16-9P	9	36	2.3	TYPE I	
109+44.91	55.00 LT	D3-2 Modified (KDOT SPECIAL)	60	18	7.5	TYPE I	13
112+90.07	54.44 LT	R10-7	24	30	5	TYPE I	14
113+21.22	77.34 LT	R1-1	36	36	9	TYPE 2	15
113+32.88	50.81 RT	W1-7	48	24	8	TYPE I	14

REMOVE SIGN PANEL ASSEMBLY			
STATION	OFFSET	TYPE	QUANTITY
	(LT/RT)		(EACH)
RANDALL ROAD			
90+08.09	51.55 RT	B	1
93+59.84	55.96 RT	B	1
96+35.67	58.65 RT	A	1
98+84.18	16.05 LT	B	1
99+74.46	104.19 RT	B	1
100+03.52	112.40 LT	B	1
100+89.83	7.83 RT	B	1
104+83.38	50.56 RT	A	1
106+36.72	57.55 LT	B	1
108+83.66	50.78 RT	B	1
109+43.59	49.14 LT	B	1
113+24.53	77.30 LT	A	1
113+46.09	47.07 RT	B	1
IL ROUTE 72 (HIGGINS ROAD)			
190+97.52	42.95 RT	B	1

REMOVE SIGN PANEL			
STATION	OFFSET	TYPE	QUANTITY
	(LT/RT)		(SQ FT)
RANDALL ROAD			
96+38.98	56.12 LT	2	12
98+82.48	57.17 RT	1	9
99+28.19	126.76 RT	1	5
100+51.93	126.77 LT	1	5
100+77.77	62.43 RT	1	4

RELOCATE SIGN PANEL ASSEMBLY- TYPE B		
STATION	OFFSET	QUANTITY
	(LT/RT)	(EACH)
RANDALL ROAD		
97+89.97	68.05 LT	1
102+91.30	52.62 RT	1
112+89.95	54.53 LT	2
IL ROUTE 72 (HIGGINS ROAD)		

IL ROUTE 72 (HIGGINS ROAD)							
STATION	OFFSET	SIGN DESIGNATION	SIZE (L x H) (INCH)		AREA (SF)	SIGN TYPE	POST LENGTH (FT)
190+95.40	41.02 RT	W3-3	36	36	9.0	TYPE 2	17
		W16-9P	21	9	1.3	TYPE I	
191+72.74	55.05 LT	R2-1	30	36	7.5	TYPE I	15
192+80.79	12.39 LT	R3-8	30	36	7.5	TYPE I	11
193+69.32	56.14 RT	D1-2	48	30	10.0	TYPE 2	LIGHT POLE
195+38.60	58.83	R3-7R	36	36	9.0	TYPE 2	LIGHT POLE
198+08.55	58.92 LT	W4-2	48	48	16.0	TYPE 2	14
201+78.42	63.26 RT	W9-1R	48	48	16.0	TYPE 2	14
203+70.83	64.31 LT	D1-2	48	30	10.0	TYPE 2	13
206+18.66	62.35 LT	D4-2	30	36	7.5	TYPE I	14



BLA, Inc.

USER NAME = cesario	DESIGNED - TN	REVISED -
	DRAWN - TN	REVISED -
PLOT SCALE = 2.0000 ' / in.	CHECKED - GJE	REVISED -
PLOT DATE = 6/19/2025	DATE - 02/15/2025	REVISED -


STATE OF ILLINOIS
DEPARTMENT OF TRANSPORTATION

RANDALL ROAD AT IL ROUTE 72 (HIGGINS ROAD)
SCHEDULE OF SIGNS

SCALE: N/A SHEET 1 OF 1 SHEETS STA. N/A TO STA. N/A

F.A.P. RTE.:	SECTION	COUNTY	TOTAL SHEETS	SHEET NO.
0336	19-00514-00-WR	KANE	304	141
CONTRACT NO. 61L28				
ILLINOIS FED. AID PROJECT				

MODEL: Detail
FILE NAME: V:\894-088 Randall at Higgins Phase II Engineering\CADD Sheets\013 PMK and Signing Plans\15-005 4-00-VIR SHI PMK DETAILS.dgn

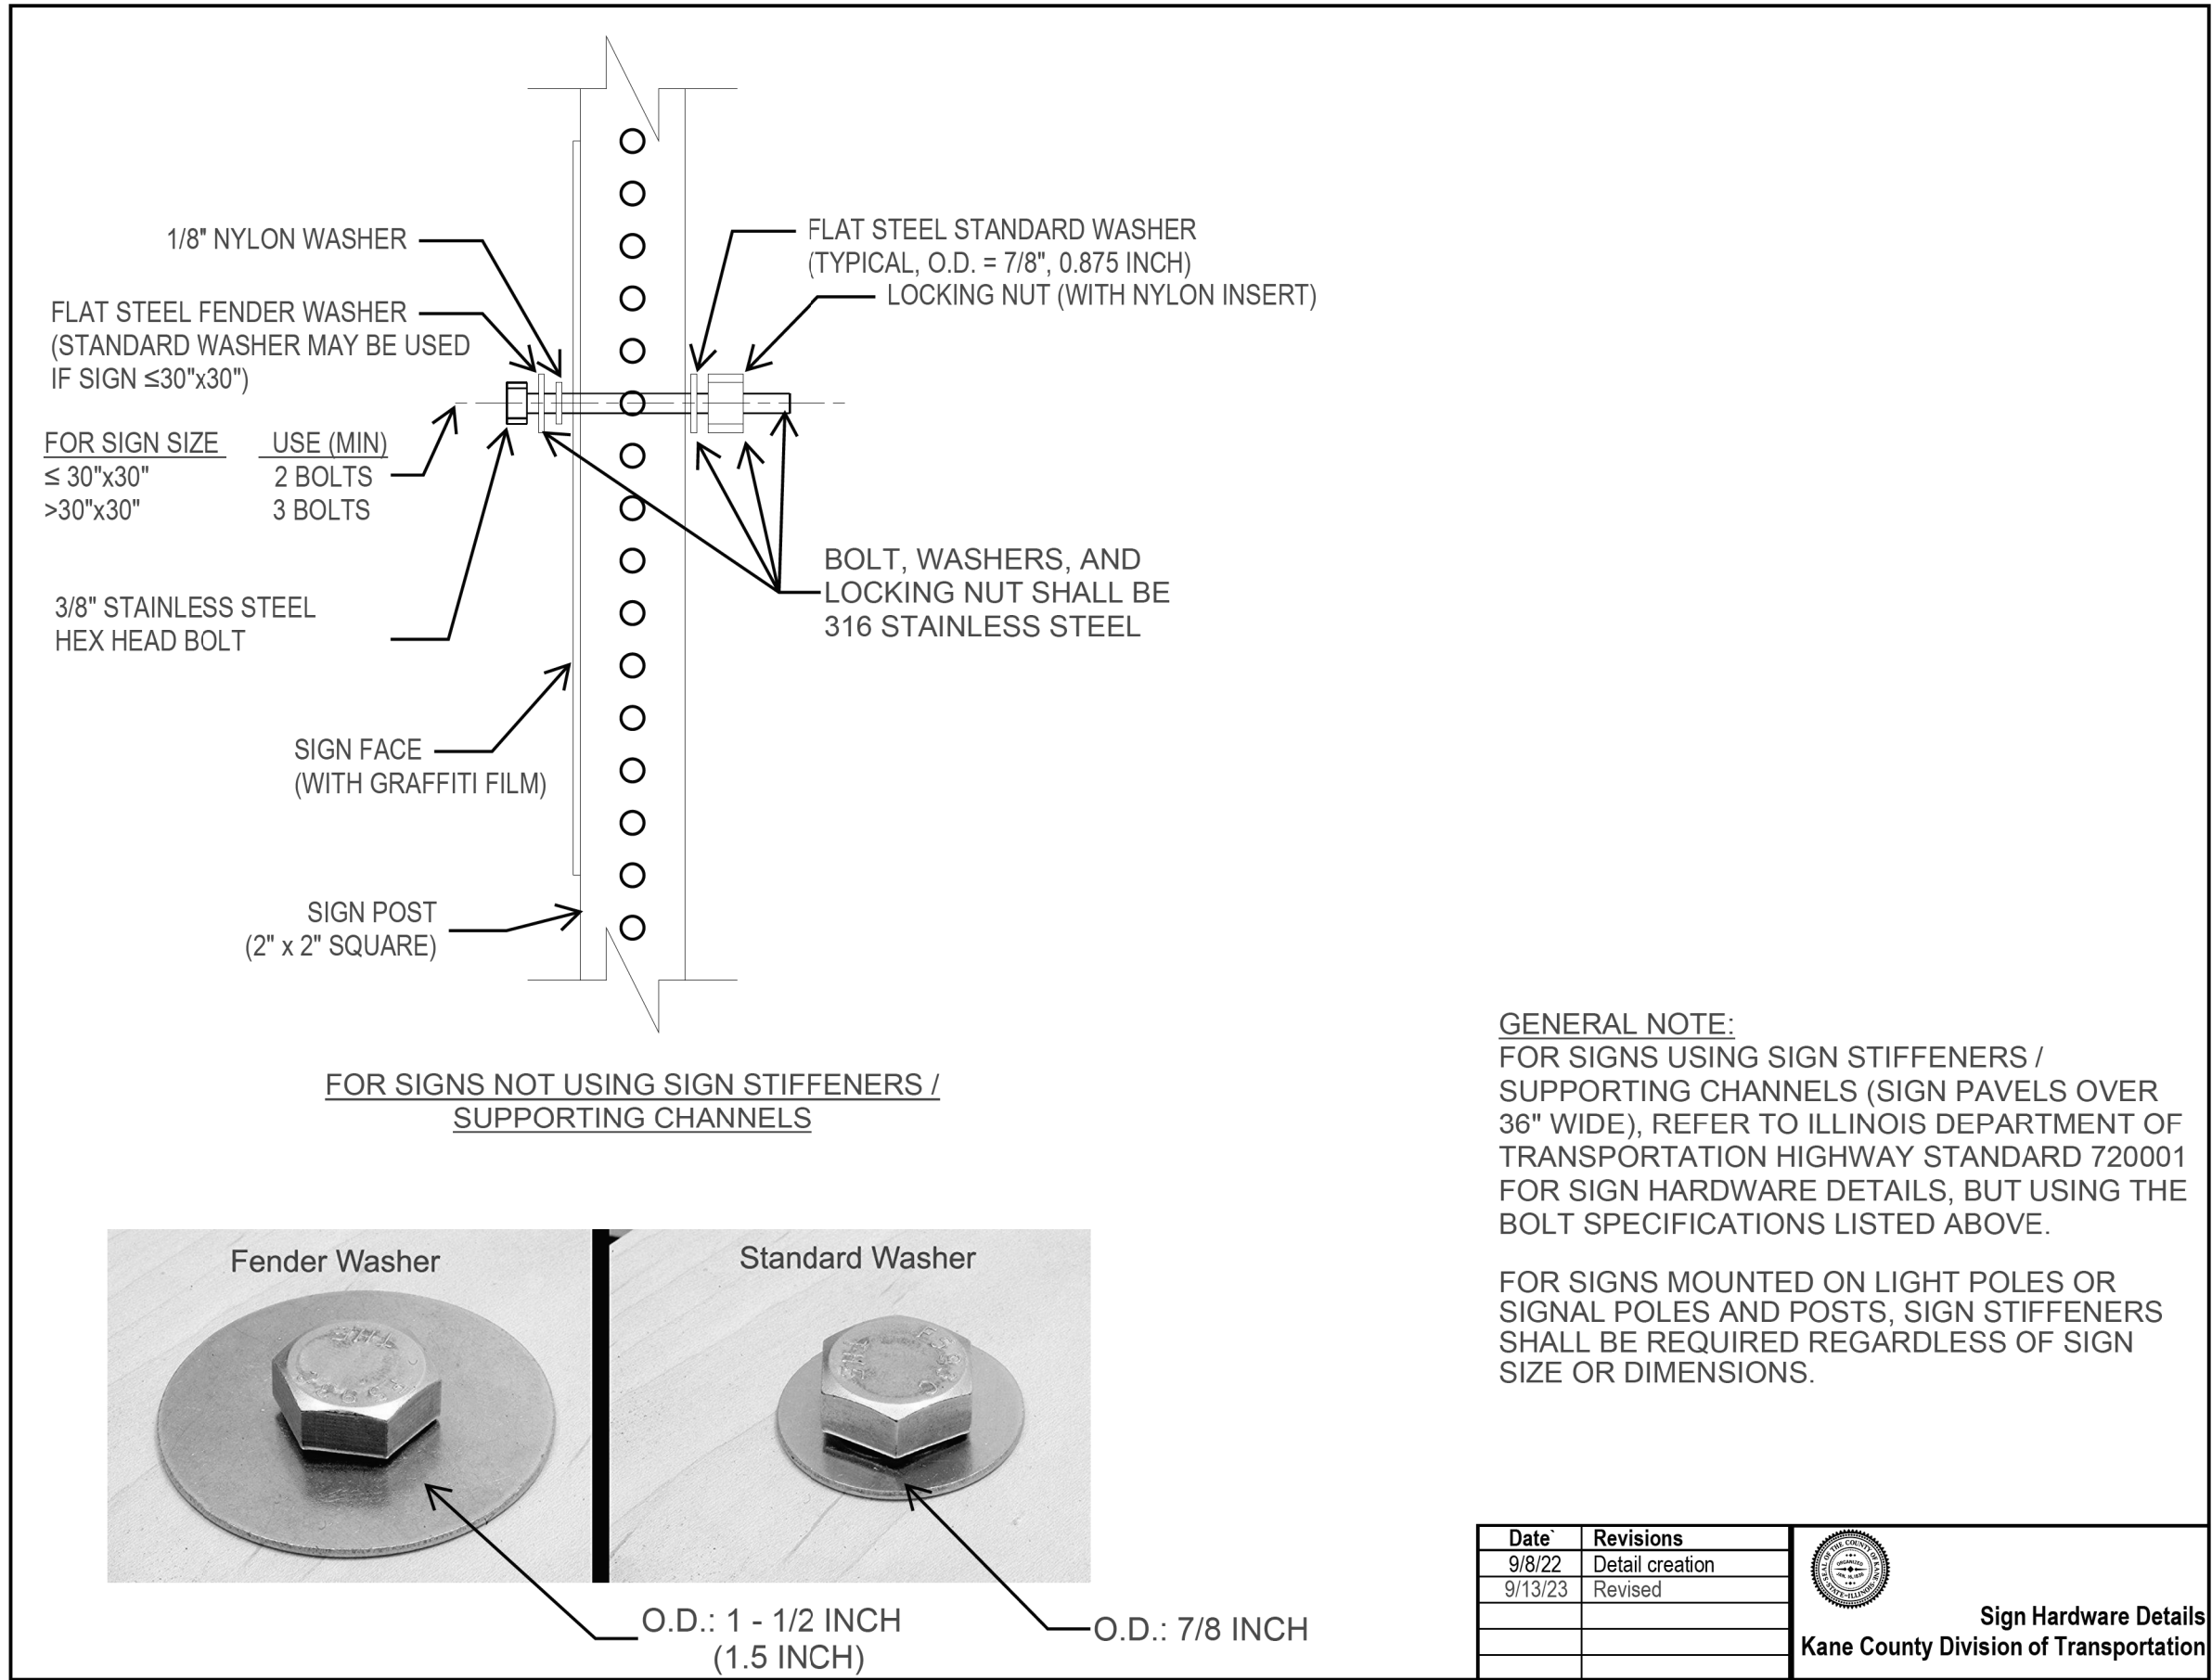

BLA, Inc.

USER NAME = cesario	DESIGNED - TN	REVISED -
	DRAWN - TN	REVISED -
PLOT SCALE = 48.0000' / 1"	CHECKED - GJE	REVISED -
PLOT DATE = 6/19/2025	DATE - 02/15/2025	REVISED -

**STATE OF ILLINOIS
DEPARTMENT OF TRANSPORTATION**

**RANDALL ROAD AT IL ROUTE 72 (HIGGINS ROAD)
PAVEMENT MARKING AND SIGNING PLAN**

SCALE: N/A SHEET 1 OF 3 SHEETS STA. N/A TO STA. N/A

F.A.P. RTE.	SECTION	COUNTY	TOTAL SHEETS	SHEET NO.
0336	19-00514-00-WR	KANE	304	142
CONTRACT NO. 61L28				
ILLINOIS FED. AID PROJECT				

MODEL: Default
FILE NAME: W:\894-088 Randall at Higgins Phase II Engineering\CADD Sheets\013 PMK and Signing Plans\19-00514-00-WR_SHT_PMK_DETAILS.dgn



BLA, Inc.

USER NAME = cesario	DESIGNED - TN	REVISED -
	DRAWN - TN	REVISED -
PLOT SCALE = 48.0000' / in.	CHECKED - GJE	REVISED -
PLOT DATE = 6/19/2025	DATE - 02/15/2025	REVISED -

STATE OF ILLINOIS
DEPARTMENT OF TRANSPORTATION

RANDALL ROAD AT IL ROUTE 72 (HIGGINS ROAD)
PAVEMENT MARKING AND SIGNING PLAN

SCALE: N/A SHEET 2 OF 3 SHEETS STA. N/A TO STA. N/A


F.A.P. RTE.	SECTION	COUNTY	TOTAL SHEETS	SHEET NO.
0336	19-00514-00-WR	KANE	304	143
CONTRACT NO. 61L28				
ILLINOIS FED. AID PROJECT				

Telescoping Sign Post

The post shall be a square tube formed of 12 gauge steel according to the standard specification for cold rolled carbon steel sheets commercial quality ASTM A 1008 (A 1008M). The post shall be formed to size and, if necessary, shall be welded in such a manner that weld or flash shall not interfere with telescoping. Holes $7/16 \pm 1/64$ in. (11 ± 0.4 mm) will be spaced on 1 in. (25 mm) centers on at least two opposite sides. The holes shall align to accept a $3/8$ in. (10 mm) bolt through the post at any location. The post shall have a smooth galvanized finish applied either before or after forming. For all other regulations refer to Section 1093 of the latest version of Illinois Standard Specifications for Bridge and Road Construction.

Sign Bases (Soil / Ground Mount)


Shall follow IDOT Standard specifications for 728.04(b) for ground mount bases for telescoping steel sign supports. Base shall be embedded 5 feet into ground with no more than 4 inches exposed above ground level. Telescoping Steel Sign support shall extend a minimum of 8 inches into the base but no further than 12 inches into the base. Dimensions of Sign base shall be as detailed below and shall use $3/8$ inch stainless steel hex head bolts and lock nut with flat standard washers on either end. Details provided on page for reference only, detail may follow updates to IDOT Highway standard 728001, Contractor to verify with Engineer if differences are identified. Contractor shall seek approval from KDOT before signs become responsibility of KDOT.

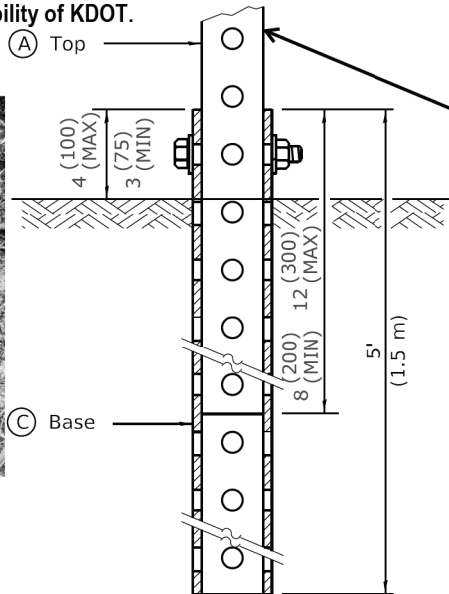

TOP SECTION SHALL
EXTEND A MINIMUM
OF 8 INCHES INTO
BASE BUT NO MORE
THAN 12 INCHES


(A)	2 x 2 x var. (51 x 51 var.)
(C)	2 1/4 x 2 1/4 x 60 (57 x 57 x 1500)

 12 Gauge Telescoping Galvanized Square Post,
2"W x 2"D x min. 10'



1" Spacings

Stainless steel bolts and washers used for fastening extruded aluminum sign panels to supports, shall be according to ASTM A 276, Type 316. Stainless steel nuts shall be according to ASTM A 240 (A 240M), Type 316.

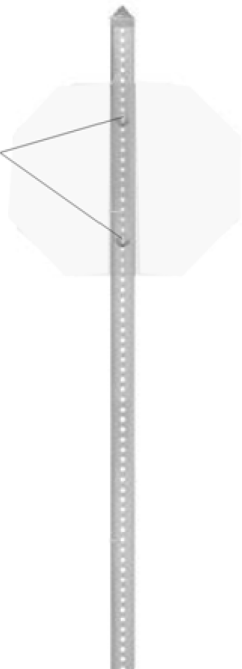

Kane County Division of Transportation

Specifications
Telescoping Sign Post
&
Soil Bases

GROUND MOUNT DETAIL

Date	Revisions	 Specifications Telescoping Sign Post & Soil Bases
07/17	Sign Post Base Hardware	

MODEL: Default
FILE NAME: V:\894-088 Randall at Higgins Phase II Engineering\CADD Sheets\013 PMK and Signing Plans\15005 400VIR SHI PMK DETAILS.dgn



BLA, Inc.


USER NAME = cesario	DESIGNED - TN	REVISED -
	DRAWN - TN	REVISED -
PLOT SCALE = 48.0000' / in.	CHECKED - GJE	REVISED -
PLOT DATE = 6/19/2025	DATE - 02/15/2025	REVISED -

STATE OF ILLINOIS
DEPARTMENT OF TRANSPORTATION

RANDALL ROAD AT IL ROUTE 72 (HIGGINS ROAD)
PAVEMENT MARKING AND SIGNING PLAN

SCALE: N/A SHEET 3 OF 3 SHEETS STA. N/A TO STA. N/A

F.A.P. RTE.	SECTION	COUNTY	TOTAL SHEETS	SHEET NO.
0336	19-00514-00-WR	KANE	304	144
CONTRACT NO. 61L28				
ILLINOIS FED. AID PROJECT				

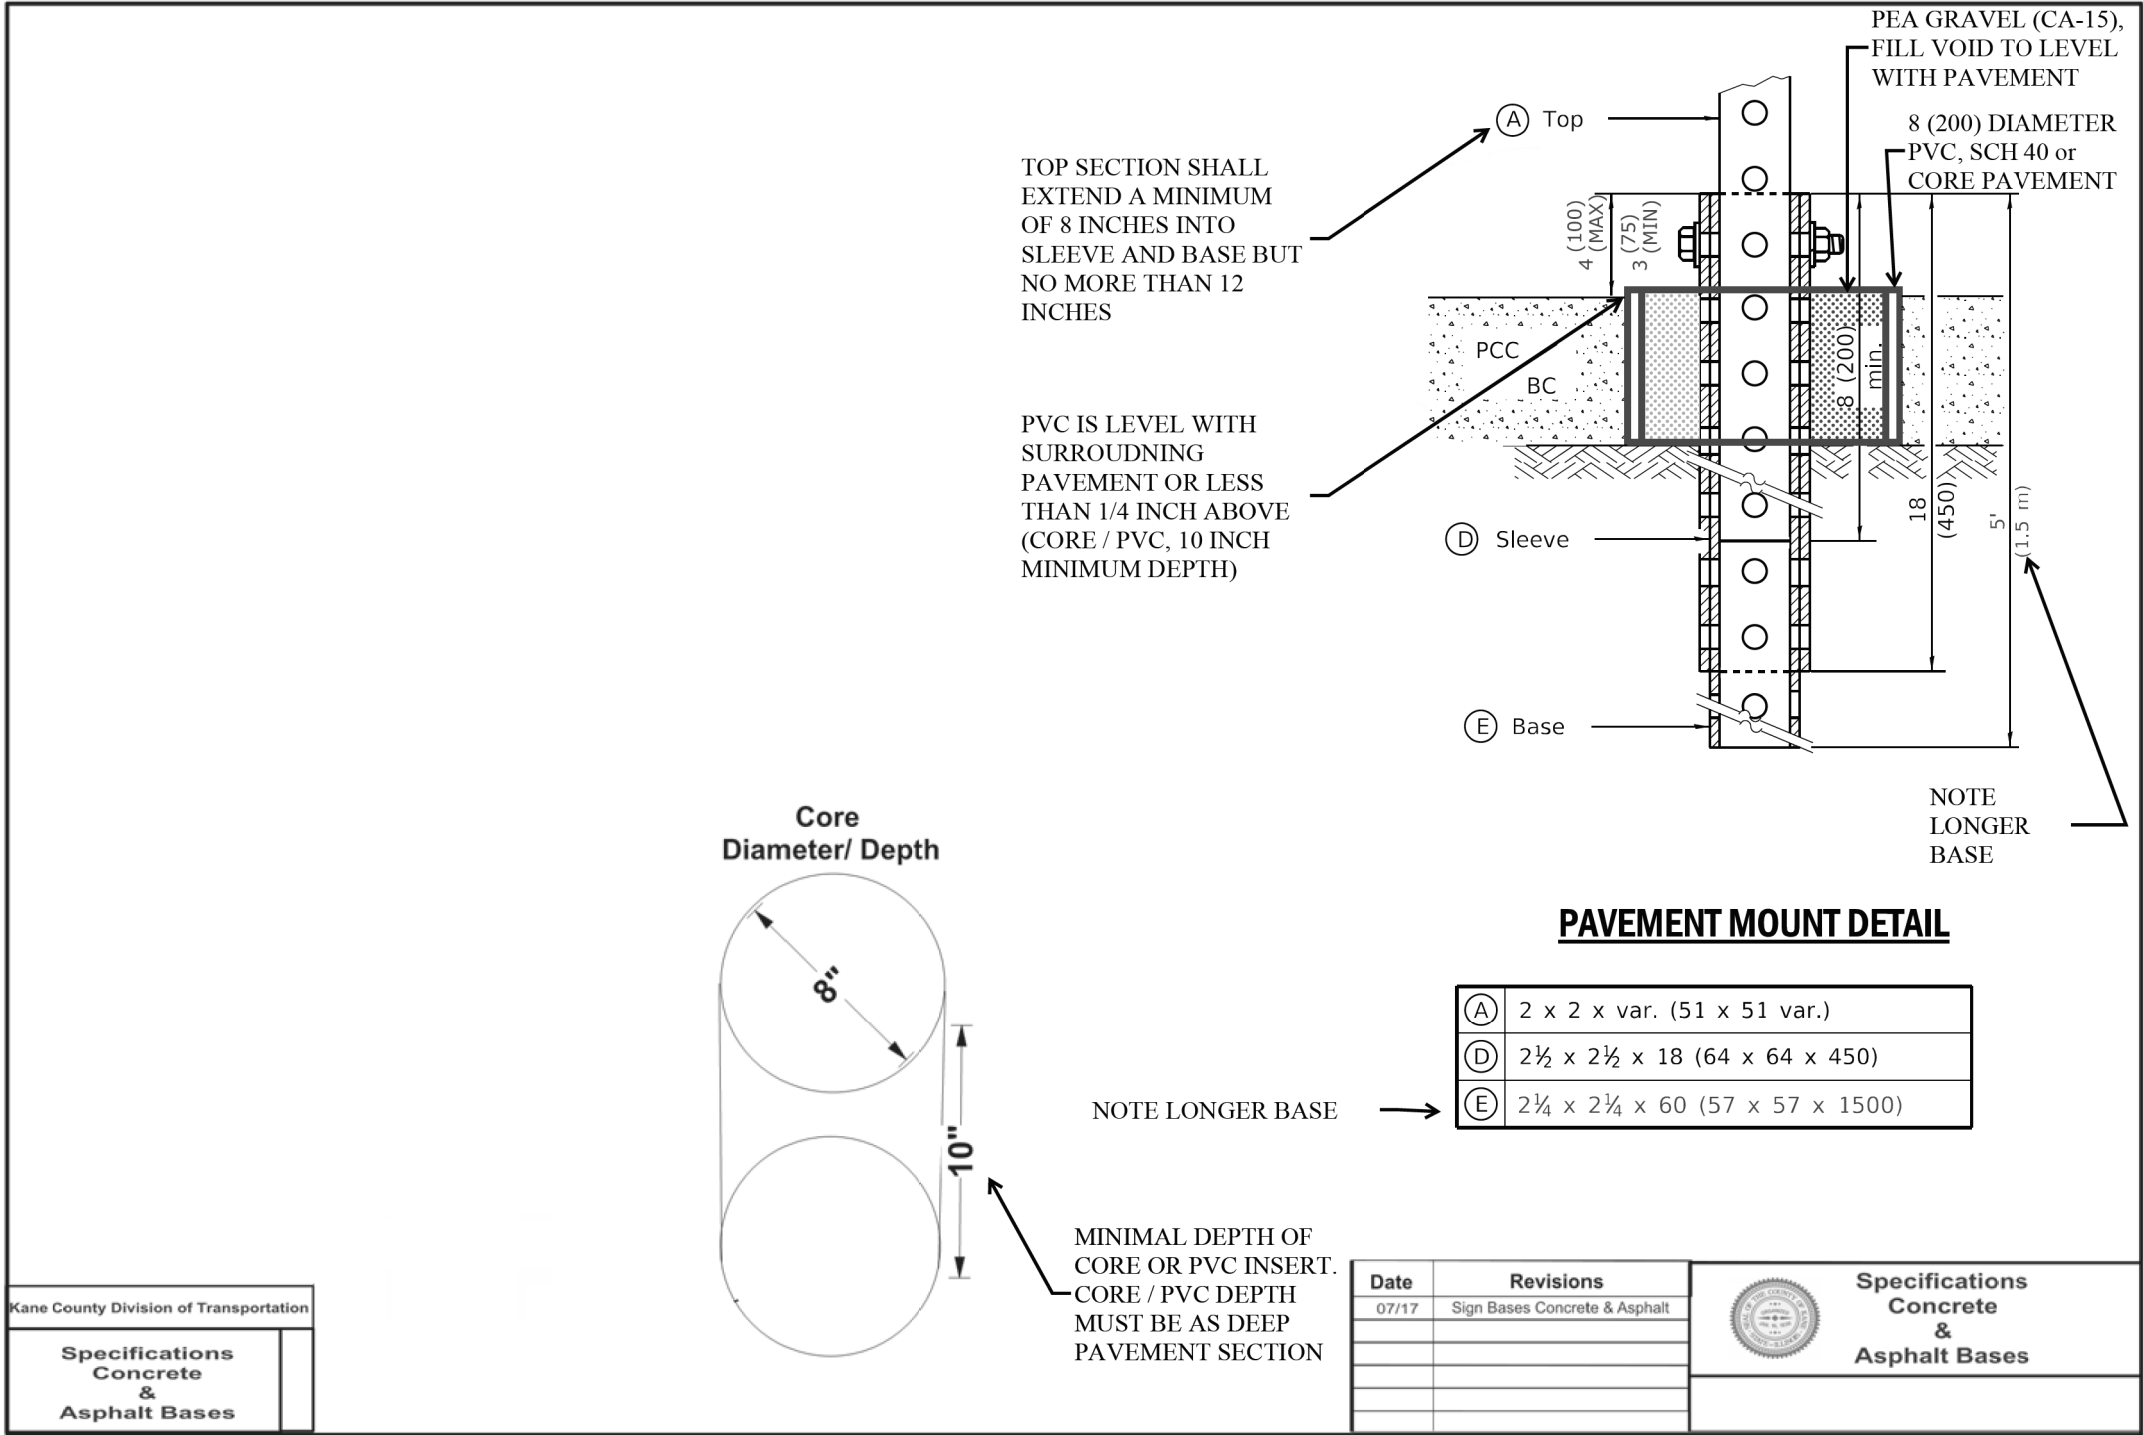

MODEL: Default
FILE NAME: V:\894-088 Randall at Higgins Phase II Engineering\CADD Sheets\014_Landscaping\Plan\19-00514-00-WR_Landscaping_001.dgn



BLA, Inc.

USER NAME = cesario	DESIGNED - TN	REVISED -
	DRAWN - TN	REVISED -
PLOT SCALE = 100.0000' / in.	CHECKED - GJE	REVISED -
PLOT DATE = 8/5/2025	DATE - 02/15/2025	REVISED -

STATE OF ILLINOIS
DEPARTMENT OF TRANSPORTATION

RANDALL ROAD AT IL ROUTE 72 (HIGGINS ROAD)
LANDSCAPE AND RESTORATION PLAN

SCALE: 1"=50' SHEET 1 OF 9 SHEETS STA. 86+50.00 TO STA. 116+50.00

F.A.P. RTE.	SECTION	COUNTY	TOTAL SHEETS	SHEET NO.
0336	19-00514-00-WR	KANE	304	145
CONTRACT NO. 61L28				
ILLINOIS FED. AID PROJECT				

LEGEND

SEEDING, CLASS 2A
WILDLIFE FRIENDLY EROSION CONTROL BLANKET
TOPSOIL EXCAVATION AND PLACEMENT, 4"


SEEDING, CLASS 4B
WILDLIFE FRIENDLY EROSION CONTROL BLANKET
TOPSOIL EXCAVATION AND PLACEMENT, 6"

SEEDING, CLASS 5B (MODIFIED)
WILDLIFE FRIENDLY EROSION CONTROL BLANKET
TOPSOIL EXCAVATION AND PLACEMENT, 6"

PERENNIAL PLANT, WETLAND TYPE,
2" DIAMETER 4" DEEP PLUG
PLANTING SOIL MIX FURNISH AND PLACE

STONE RIPRAP CLASS A3
W/ FILTER FABRIC


ARTICULATED BLOCK REVETMENT MAT
W/ FILTER FABRIC


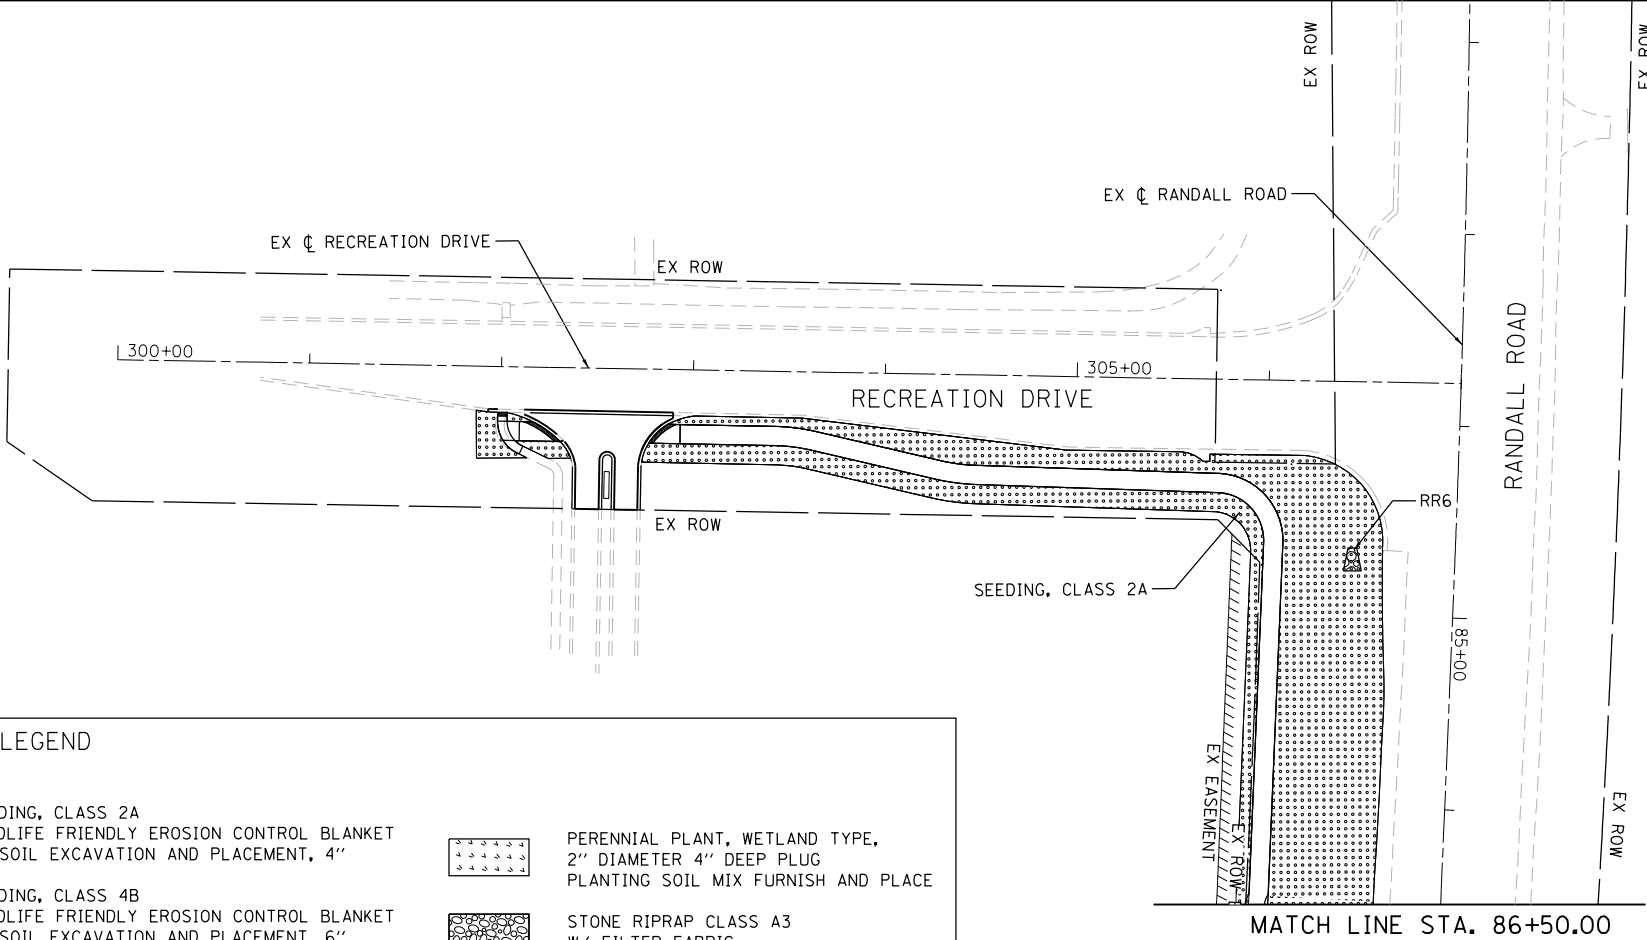


NOTE: EXISTING TOPSOIL TO BE STRIPPED, STOCKPILED AND USED AS TOPSOIL RESPREAD. PER THE DIRECTION OF THE ENGINEER IF ANY TOPSOIL IS DEEMED UNSUITABLE FOR RESPREAD, FURNISHED TOPSOIL SHALL BE FURNISHED AND PLACED ACCORDINGLY.



MODEL: Default
FILE NAME: W:\894-088 Randall at Higgins Phase II Engineering\CADD Sheets\014 Landscape\Plan\19-00514-00-WR Landscape.dwg 002.dgn

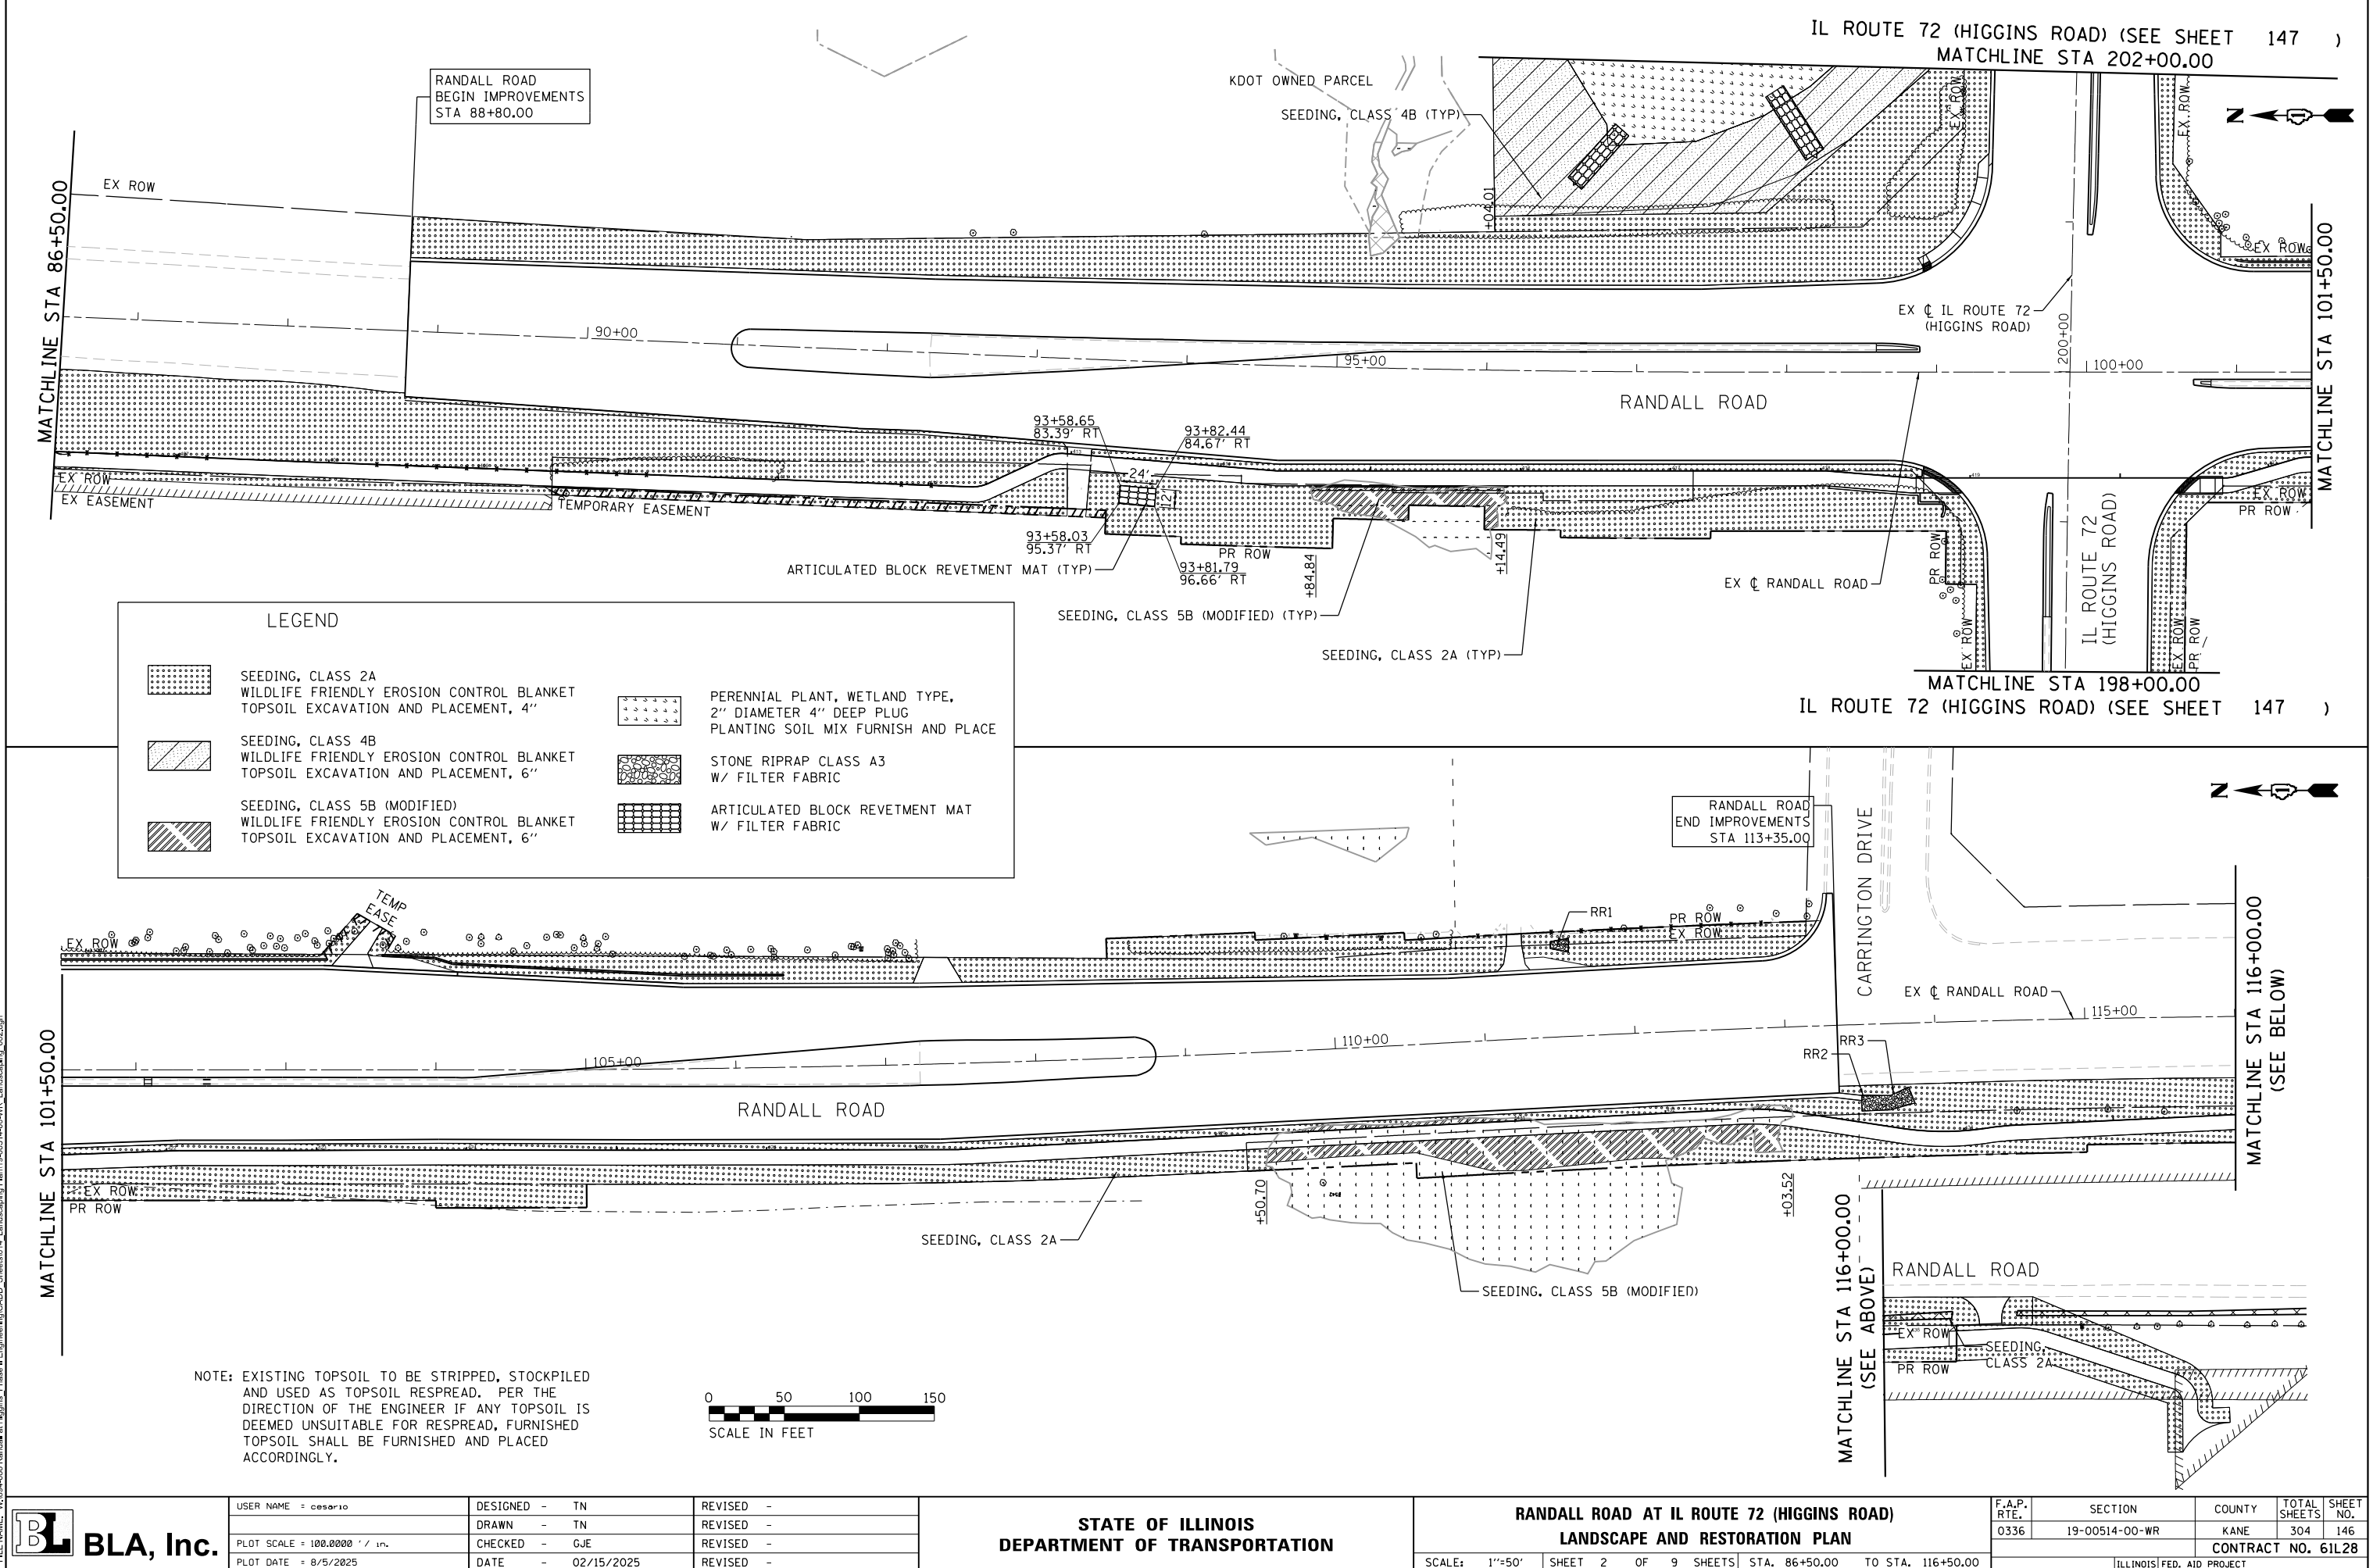

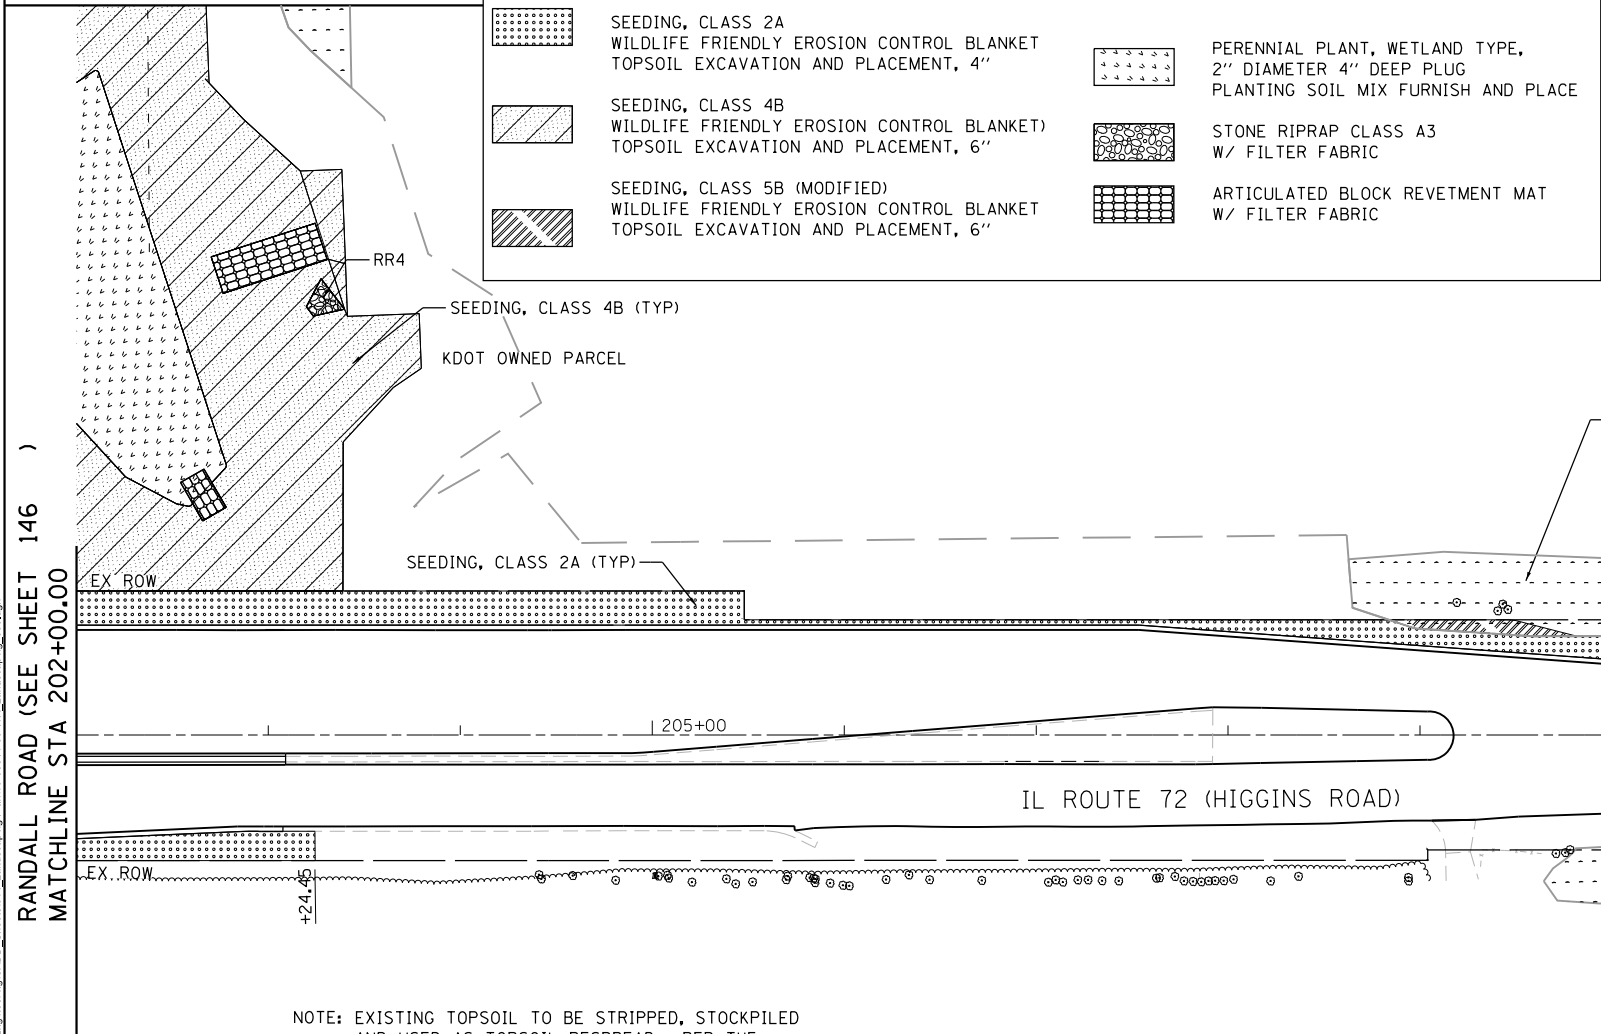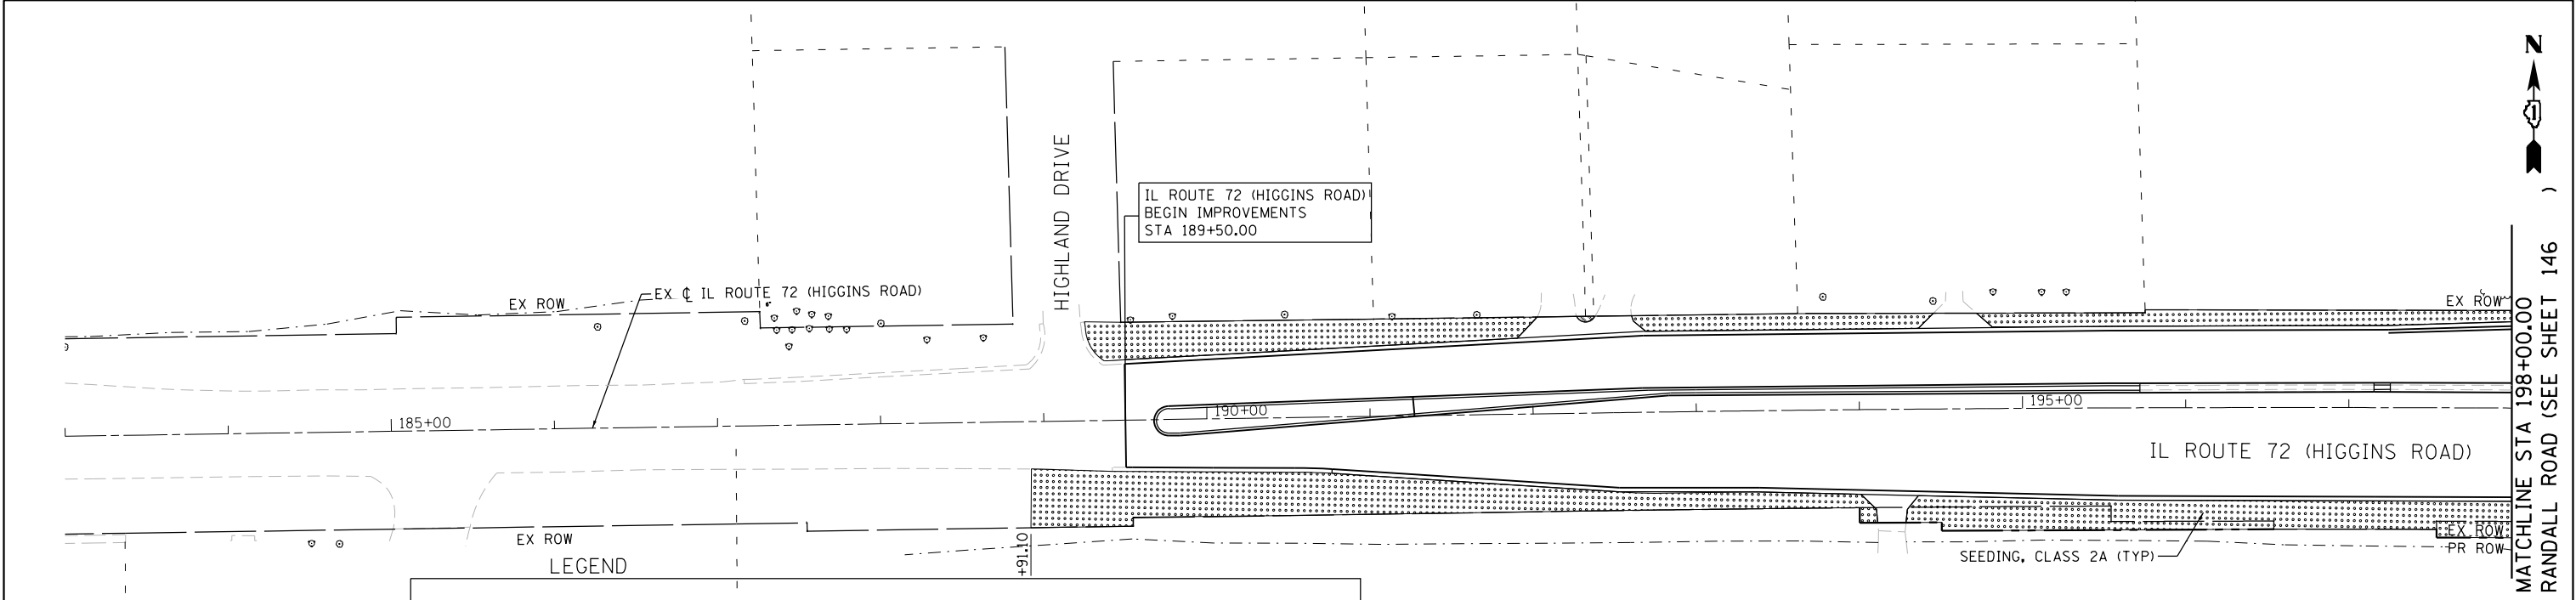

RIPRAP SIZE AND PLACEMENT												
NUMBER	ROAD	STRUCTURE STATION	STRUCTURE OFFSET	DIAMETER	IDOT ROCK GRADATION	L- APRON (FT)	W1 (FT)	W2 (FT)	Tmin (INCH)	T-bed (INCH)	RIPRAP, CLASS A3 (SQ YD)	FILTER FABRIC (SQ YD)
RR1	RANDALL	111+46.56	61.41 LT	18"	RR-3	12	4.5	9.3	8	8	8	10
RR2	RANDALL	113+49.69	49.15 RT	CURB OUTLET	RR-3	20	10	10	8	8	17	21
RR3	RANDALL	113+70.11	52.75 RT	24"	RR-3	14	10	11.6	8	8	20	20
RR4	IL ROUTE 72	203+21.65	220.63 LT	15"	RR-3	15	6	20	8	8	12	15
RR5	IL ROUTE 72	211+10.80	42.54 LT	CURB OUTLET	RR-3	20	4	8	8	8	13	17
RR6	RECREATION	306+45	86.70 RT	15"	RR-3	12	4.5	9.3	8	8	8	10
TOTAL											78	93

MODEL: Default
FILE NAME: V:\894-088 Randall at Higgins Phase II Engineering\CADD Sheets\014_Landscaping\Plan\19-00514-00-WR_Landscaping_003.dgn

RANDALL ROAD (SEE SHEET 146)
MATCHLINE STA 202+00.00

BLA, Inc.

USER NAME = cesario
PLOT SCALE = 100.0000 ' / in.
PLOT DATE = 8/5/2025

DESIGNED - TN
DRAWN - TN
CHECKED - GJE
DATE - 02/15/2025

REVISED -
REVISED -
REVISED -
REVISED -

STATE OF ILLINOIS
DEPARTMENT OF TRANSPORTATION

RANDALL ROAD AT IL ROUTE 72 (HIGGINS ROAD)
LANDSCAPING PLAN

SCALE: 1"=50' SHEET 3 OF 9 SHEETS STA. 86+50.00 TO STA. 116+50.00

F.A.P. RTE. 0336
SECTION 19-00514-00-WR
COUNTY KANE
TOTAL SHEETS 304
SHEET NO. 147
CONTRACT NO. 61L28
ILLINOIS FED. AID PROJECT

NOTE: EXISTING TOPSOIL TO BE STRIPPED, STOCKPILED AND USED AS TOPSOIL RESPREAD. PER THE DIRECTION OF THE ENGINEER IF ANY TOPSOIL IS DEEMED UNSUITABLE FOR RESPREAD, FURNISHED TOPSOIL SHALL BE FURNISHED AND PLACED ACCORDINGLY.

0 50 100 150
SCALE IN FEET

MODEL: Default
FILE NAME: V:\994-088 Randall at Higgins Phase II Engineering\CADD Sheets\014 Landscaping Plan\9940514-00-WR Landscaping Basin 004.dgn

LEGEND

- 

SEEDING, CLASS 2A
WILDLIFE FRIENDLY EROSION CONTROL BLANKET
TOPSOIL EXCAVATION AND PLACEMENT, 4"
- 

SEEDING, CLASS 4B
WILDLIFE FRIENDLY EROSION CONTROL BLANKET
TOPSOIL EXCAVATION AND PLACEMENT, 6"
- 


SEEDING, CLASS 5B (MODIFIED)
WILDLIFE FRIENDLY EROSION CONTROL BLANKET
TOPSOIL EXCAVATION AND PLACEMENT, 6"
- 

PERENNIAL PLANT, WETLAND TYPE,
2" DIAMETER 4" DEEP PLUG
PLANTING SOIL MIX FURNISH AND PLACE
- 

STONE RIPRAP CLASS A3
W/ FILTER FABRIC
- 

ARTICULATED BLOCK REVETMENT MAT
W/ FILTER FABRIC

NOTE: PERENNIAL PLANTINGS SHALL ALTERNATE
TYPES AS INDICATED IN SPECS.

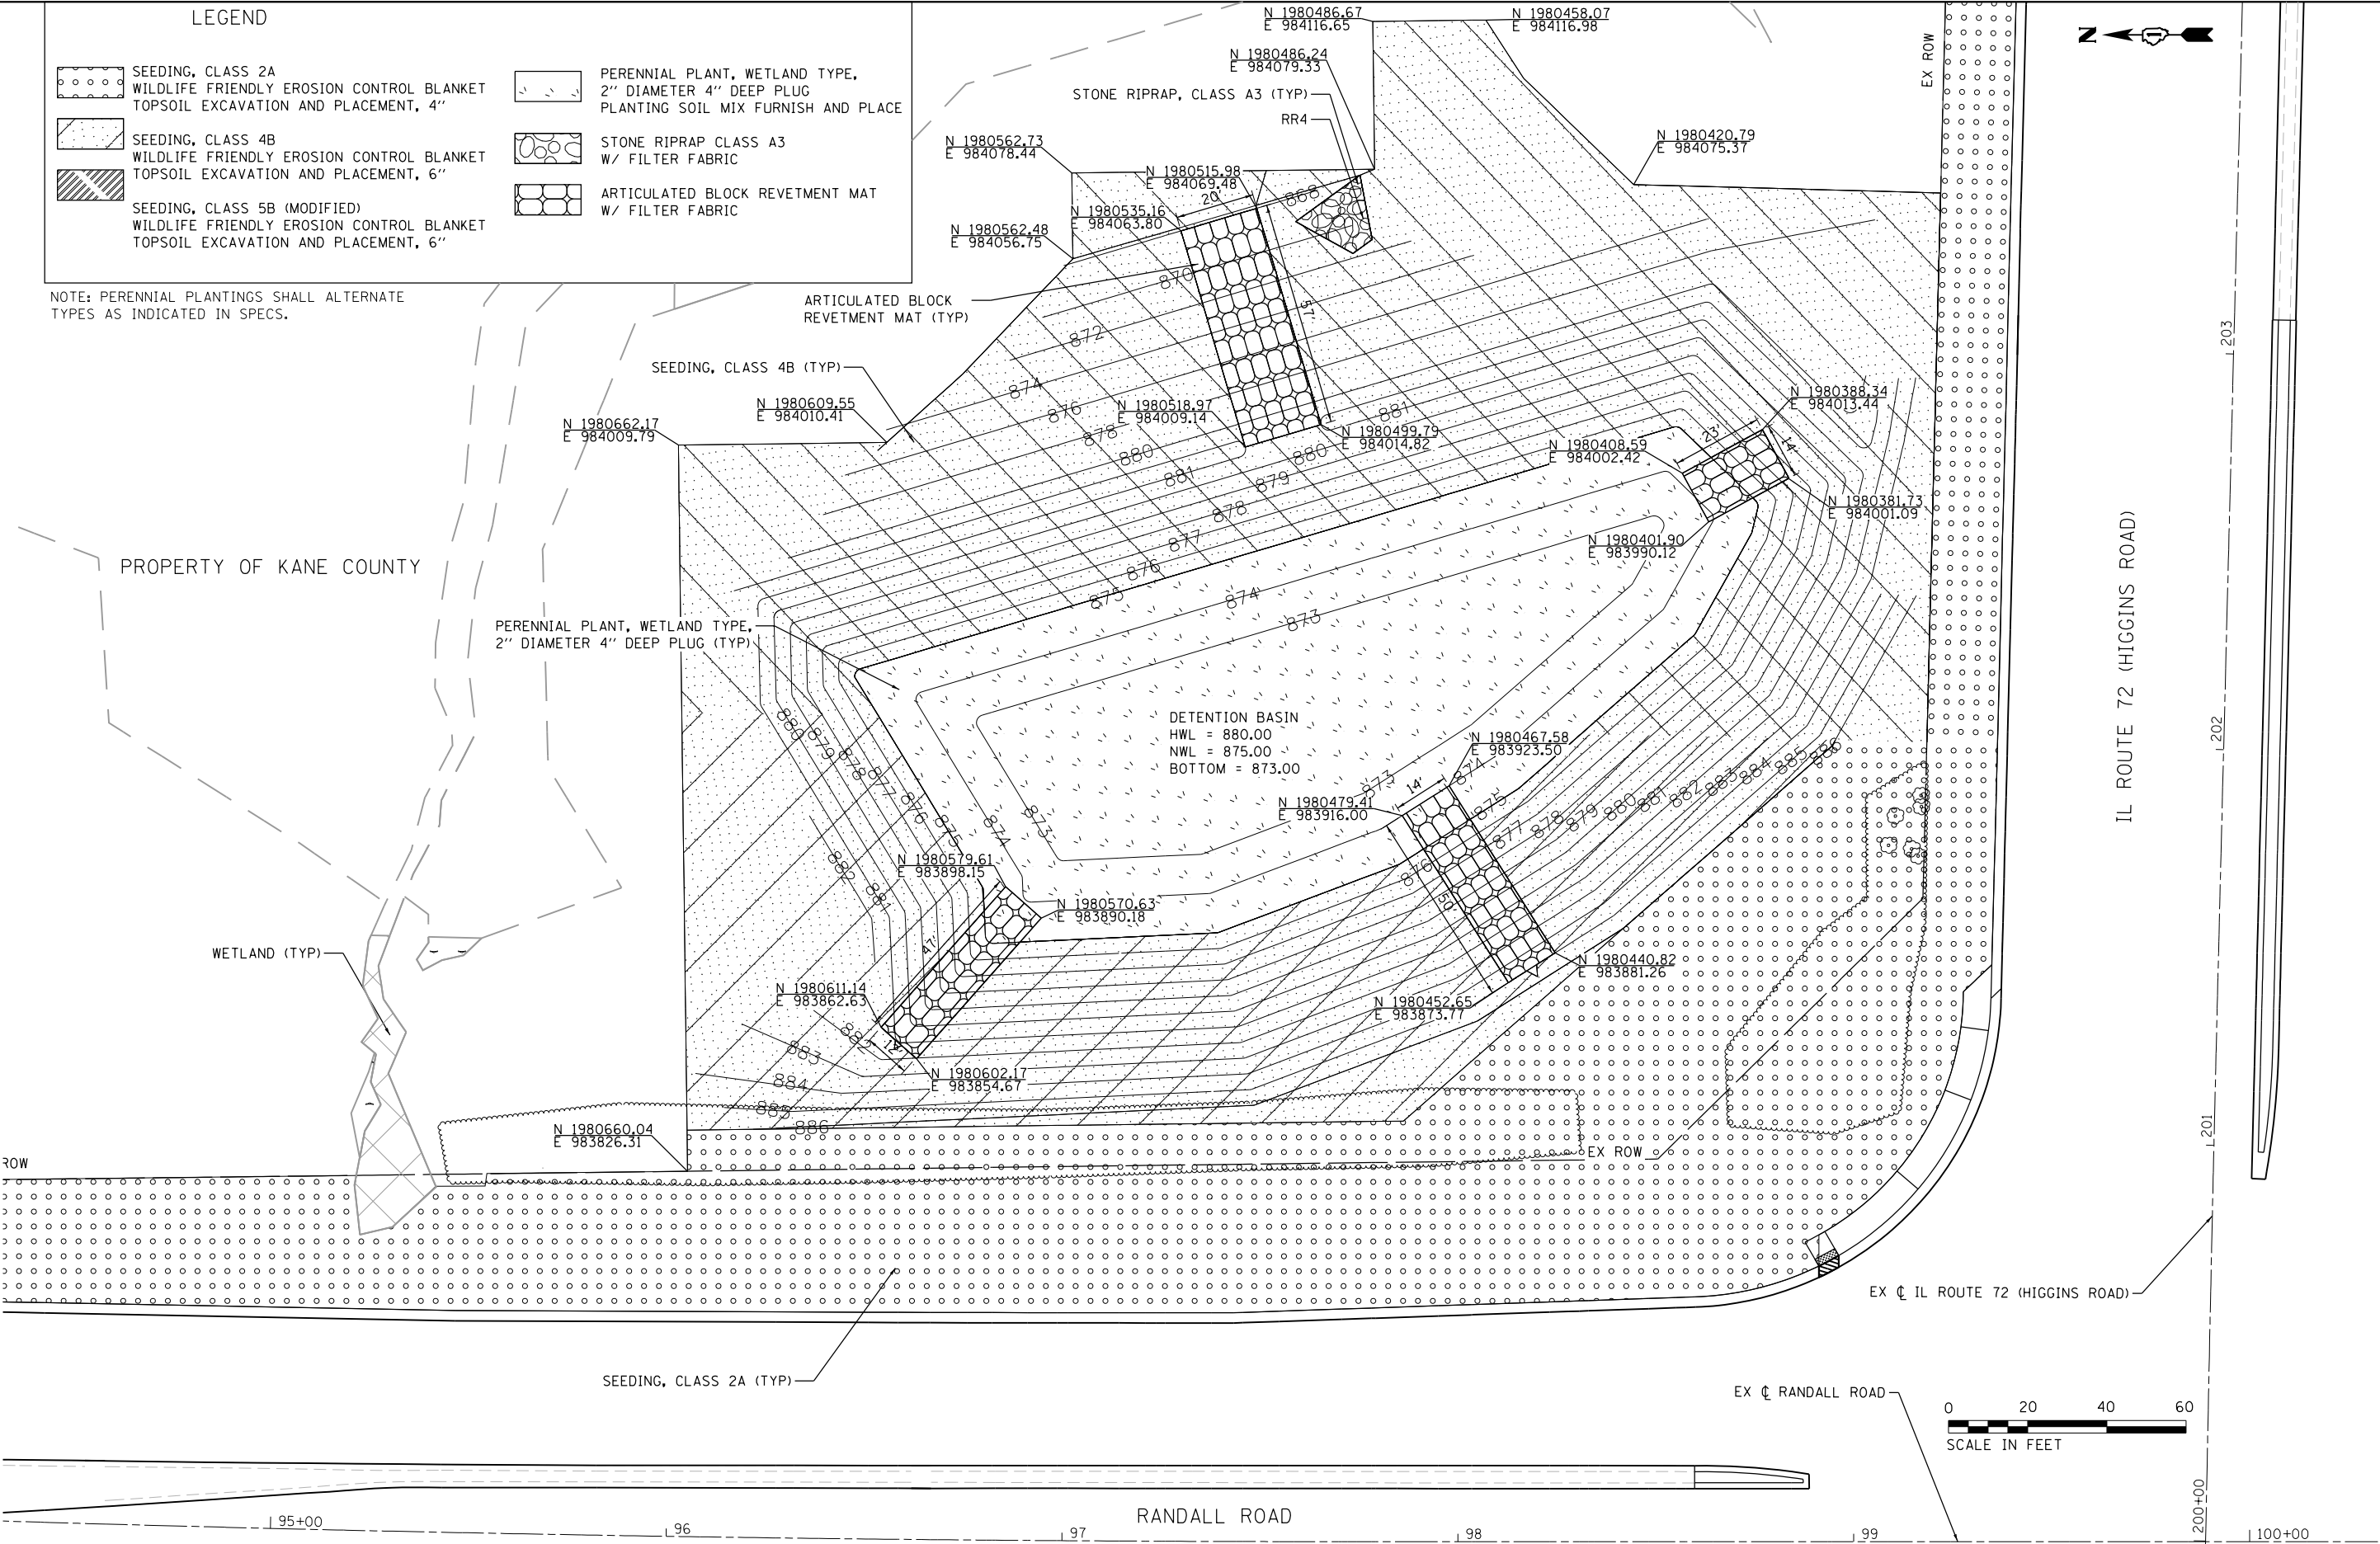

BLA, Inc.

USER NAME = cesario	DESIGNED - TN	REVISED -
	DRAWN - TN	REVISED -
PLOT SCALE = 48.0000' / in.	CHECKED - GJE	REVISED -
PLOT DATE = 8/5/2025	DATE - 02/15/2025	REVISED -


STATE OF ILLINOIS
DEPARTMENT OF TRANSPORTATION

RANDALL ROAD AT IL ROUTE 72 (HIGGINS ROAD)
DETENTION BASIN LANDSCAPING PLAN

SCALE: 1"=20' SHEET 4 OF 9 SHEETS STA. NA TO STA. NA

F.A.P. RTE.	SECTION	COUNTY	TOTAL SHEETS	SHEET NO.
0336	19-00514-00-WR	KANE	304	148
CONTRACT NO. 61L28				
ILLINOIS FED. AID PROJECT				

MODEL: Default
FILE NAME: W:\044088 Randall at Higgins Phase II Engineering\CADD Sheets\014_Landscaping Plan\040514-00-WR_Tree Planting 01.dgn

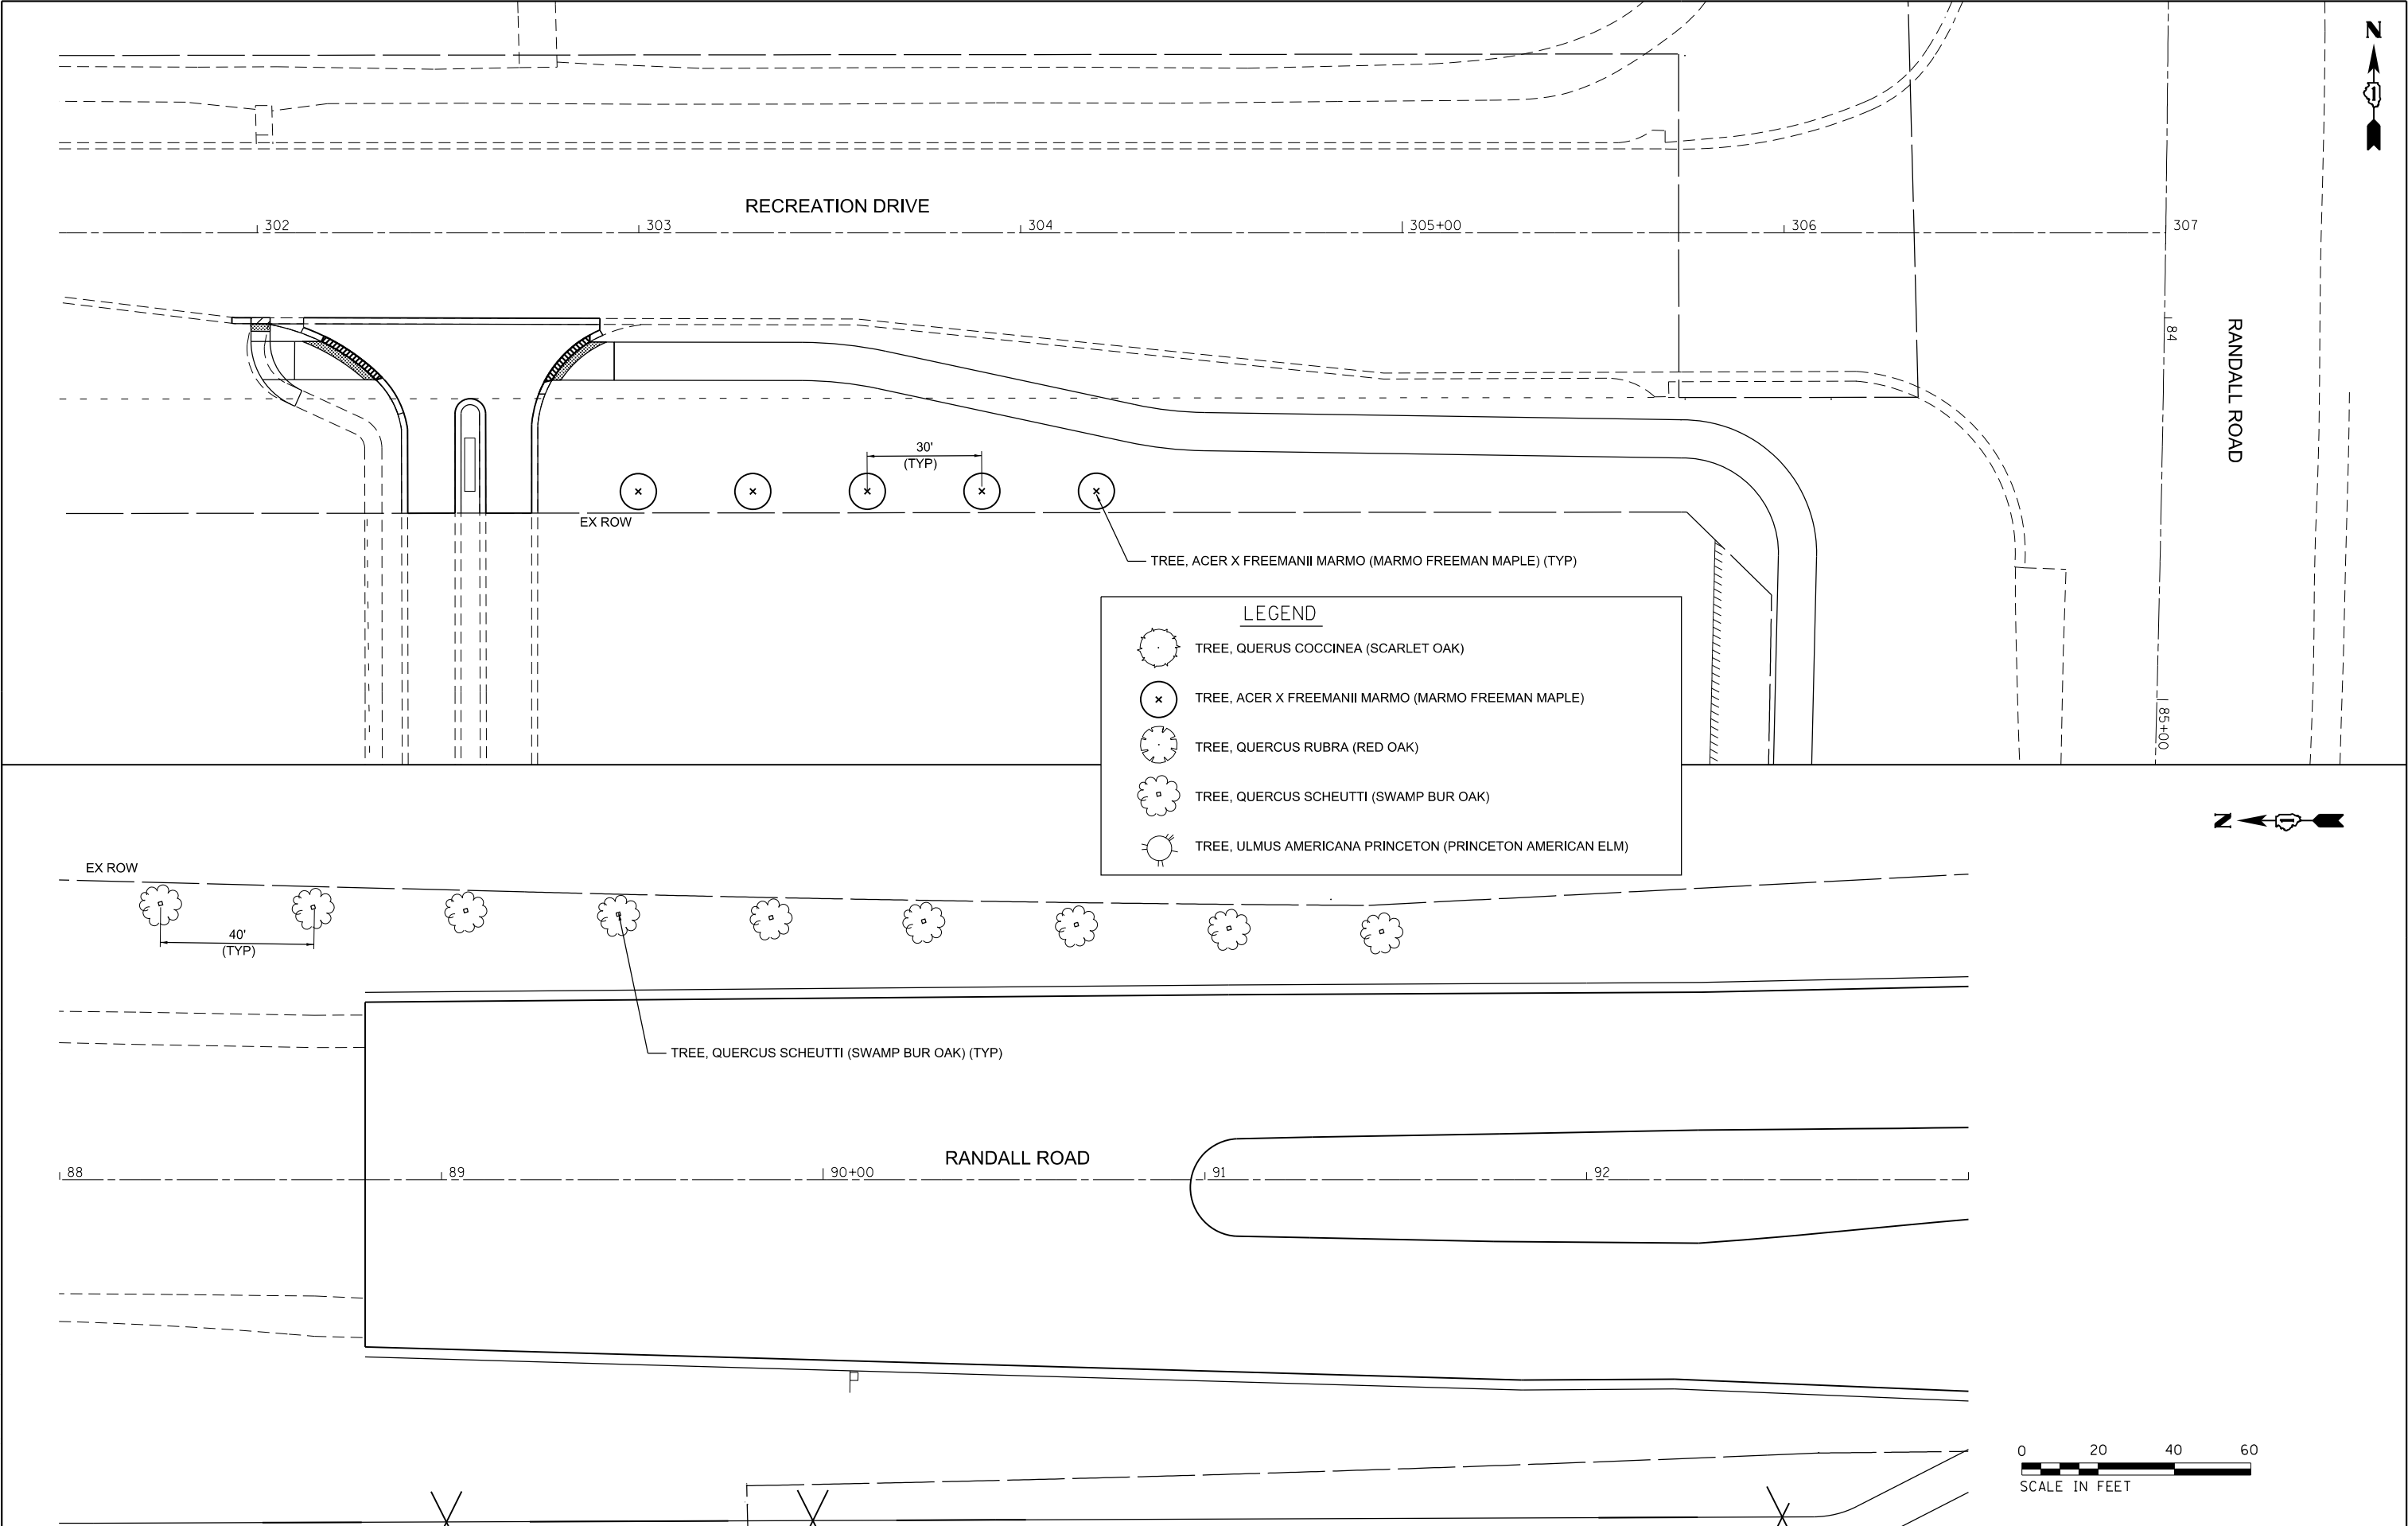

BLA, Inc.	USER NAME = cesario	DESIGNED - TN	REVISED -	STATE OF ILLINOIS DEPARTMENT OF TRANSPORTATION	RANDALL ROAD AT IL ROUTE 72 (HIGGINS ROAD) TREE PLANTING PLAN			F.A.P. RTE.	SECTION	COUNTY	TOTAL SHEETS	SHEET NO.
	PLOT SCALE = 40.0000' / in.	DRAWN - TN	REVISED -					0336	19-00514-00-WR	KANE	304	149
	PLOT DATE = 6/19/2025	CHECKED - GJE	REVISED -		SCALE: 1" = 20' SHEET 5 OF 9 SHEETS STA. TO STA.			CONTRACT NO. 61L28				
		DATE - 02/15/2025	REVISED -					ILLINOIS FED. AID PROJECT				

MODEL: Default
FILE NAME: W:\894-088 Randall at Higgins Phase II Engineering\CADD Sheets\014_Landscaping Plan\19-00514-00-WR_Tree Planting 02.dgn



BLA, Inc.

USER NAME = cesario	DESIGNED - TN	REVISED -
	DRAWN - TN	REVISED -
PLOT SCALE = 48.0000' / in.	CHECKED - GJE	REVISED -
PLOT DATE = 6/19/2025	DATE - 02/15/2025	REVISED -


STATE OF ILLINOIS
DEPARTMENT OF TRANSPORTATION

RANDALL ROAD AT IL ROUTE 72 (HIGGINS ROAD)
TREE PLANTING PLAN

SCALE: 1"=20' SHEET 6 OF 9 SHEETS STA. NA TO STA. NA

F.A.P. RTE.:	SECTION	COUNTY	TOTAL SHEETS	SHEET NO.
0336	19-00514-00-WR	KANE	304	150
CONTRACT NO. 61L28				
ILLINOIS FED. AID PROJECT				

LEGEND	
	TREE, QUERUS COCCINEA (SCARLET OAK)
	TREE, ACER X FREEMANII MARMO (MARMO FREEMAN MAPLE)
	TREE, QUERCUS RUBRA (RED OAK)
	TREE, QUERCUS SCHEUTTI (SWAMP BUR OAK)
	TREE, ULMUS AMERICANA PRINCETON (PRINCETON AMERICAN ELM)

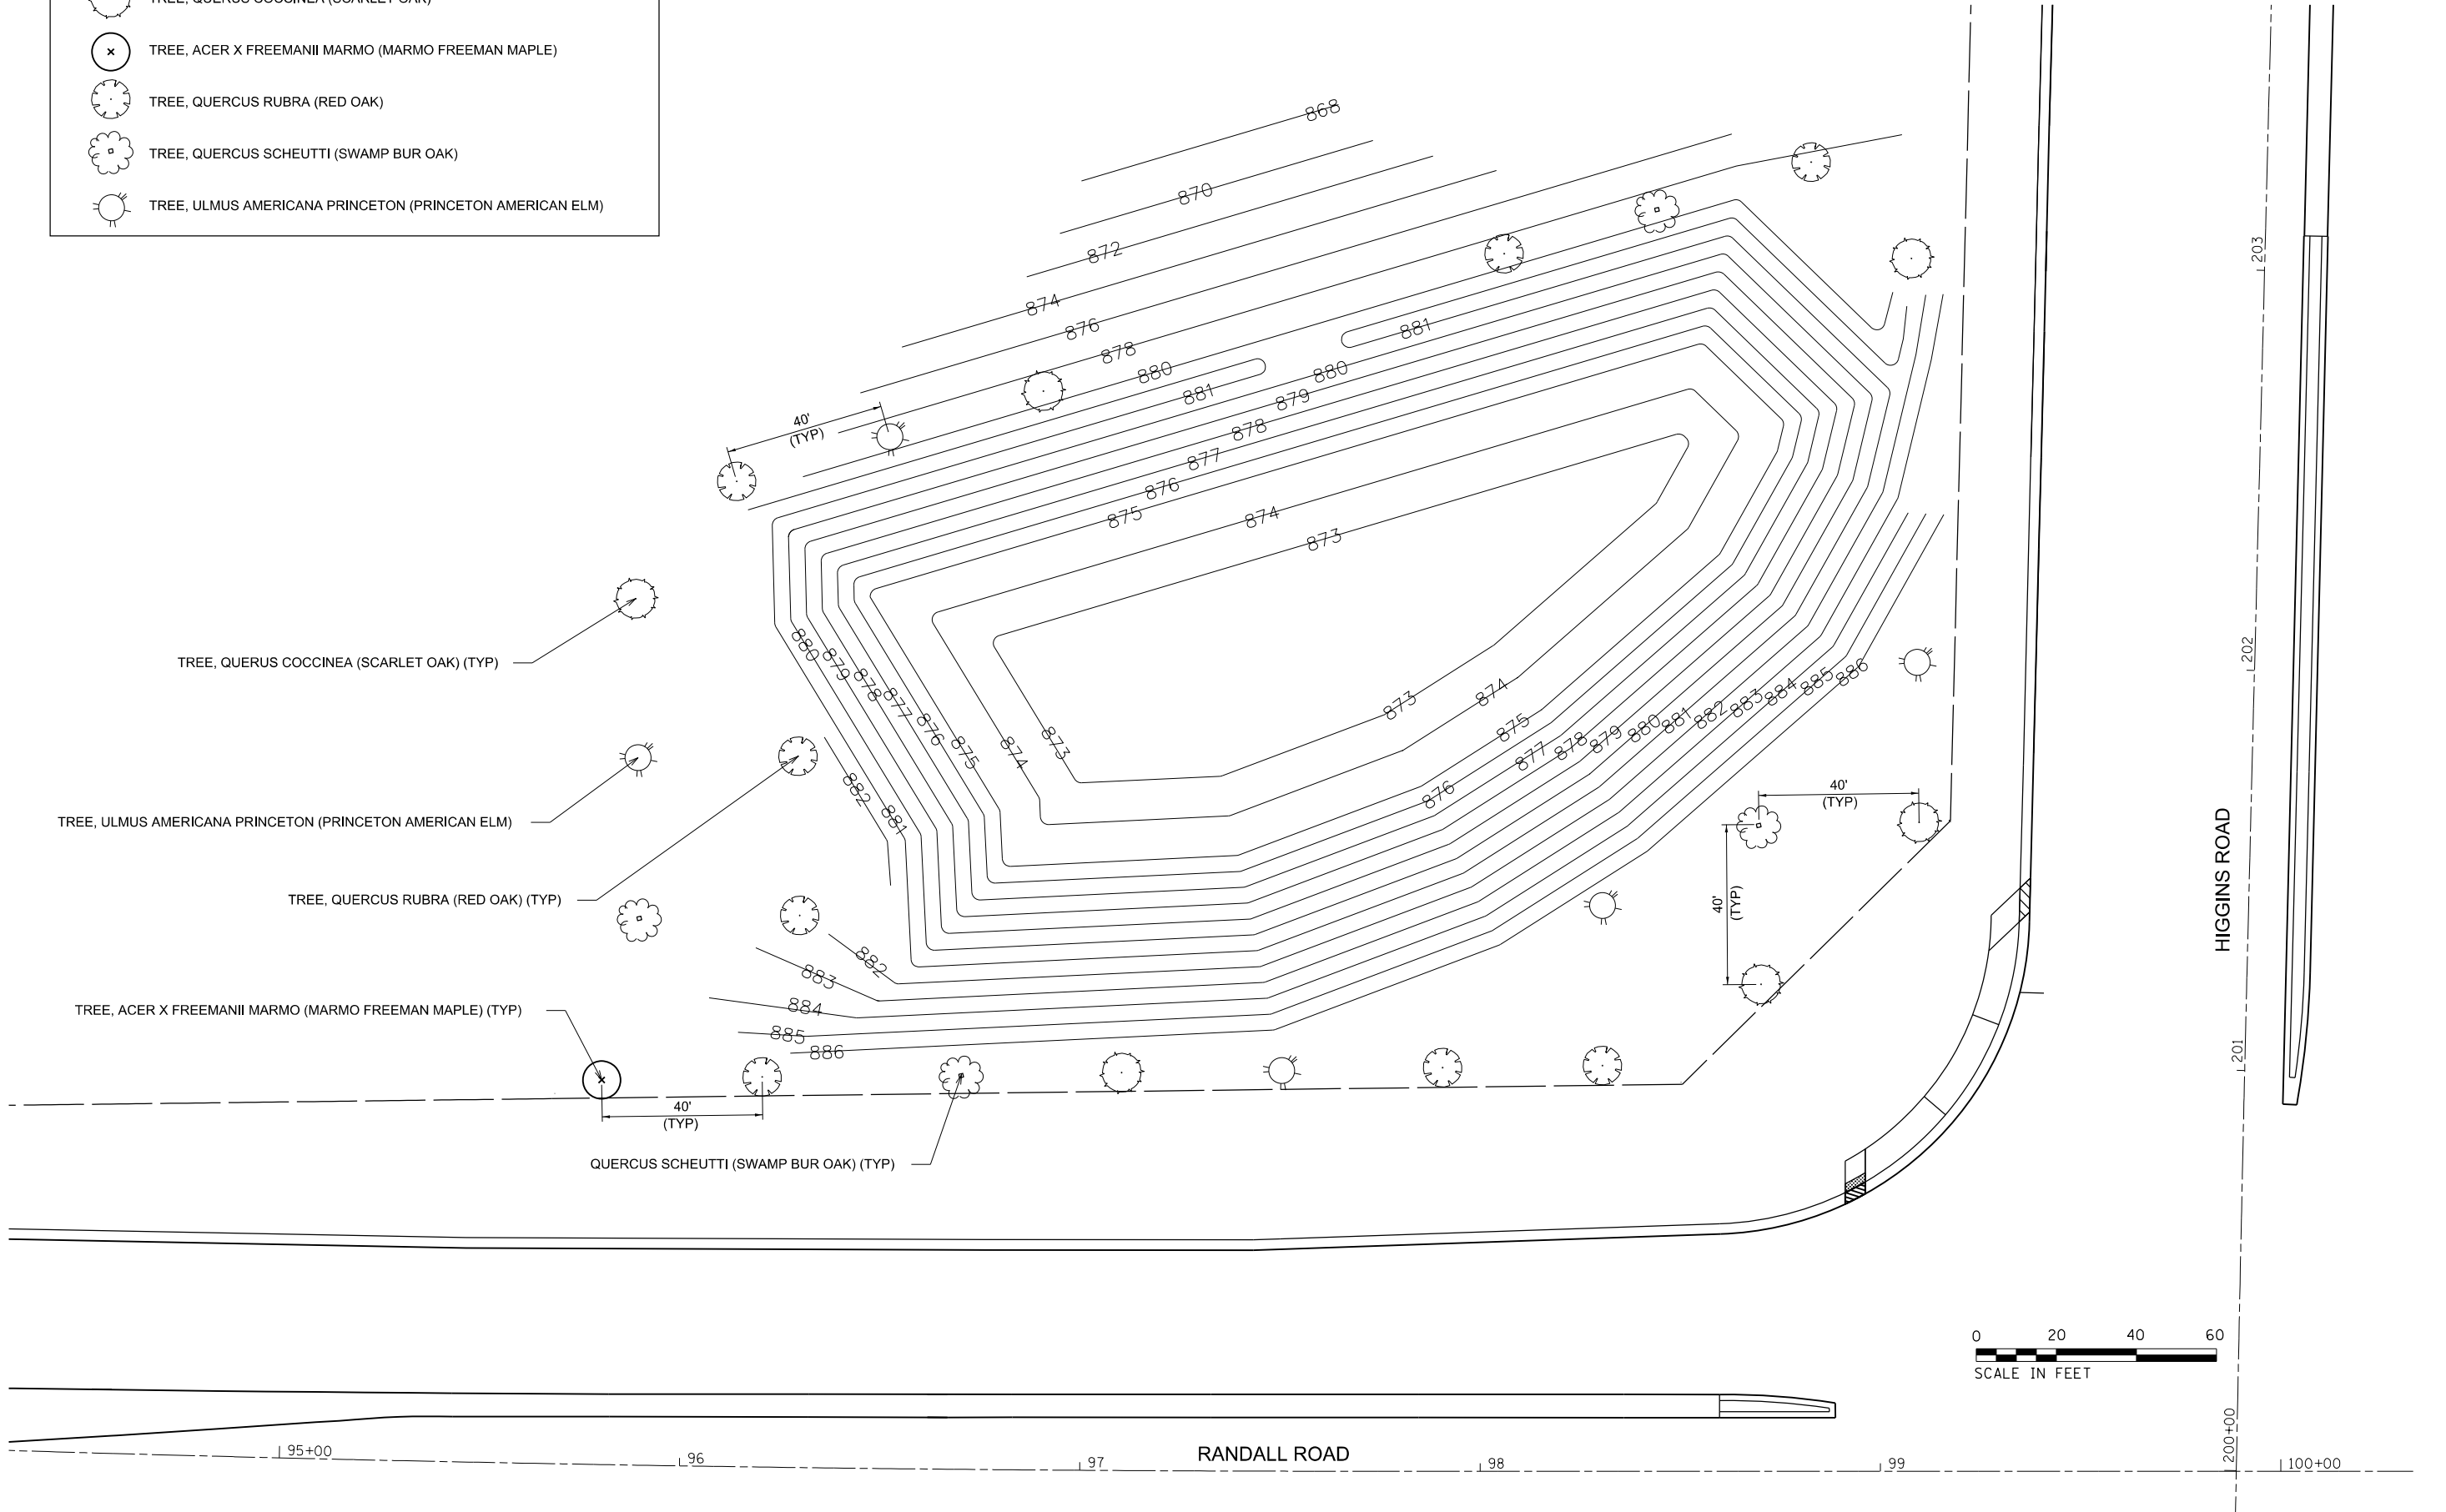

MODEL: Default
FILE NAME: W:\894-088 Randall at Higgins Phase II Engineering\CADD Sheets\014_Landscaping Plan\19-00514-00-WR_Tree Planting 03.dgn



BLA, Inc.


USER NAME = cesario	DESIGNED - TN	REVISED -
	DRAWN - TN	REVISED -
PLOT SCALE = 48.0000' / 1"	CHECKED - GJE	REVISED -
PLOT DATE = 6/19/2025	DATE - 02/15/2025	REVISED -

STATE OF ILLINOIS
DEPARTMENT OF TRANSPORTATION

RANDALL ROAD AT IL ROUTE 72 (HIGGINS ROAD)
TREE PLANTING PLAN

SCALE: 1"=20' SHEET 7 OF 9 SHEETS STA. TO STA.

F.A.P. RTE.	SECTION	COUNTY	TOTAL SHEETS	SHEET NO.
0336	19-00514-00-WR	KANE	304	151
CONTRACT NO. 61L28				
ILLINOIS FED. AID PROJECT				

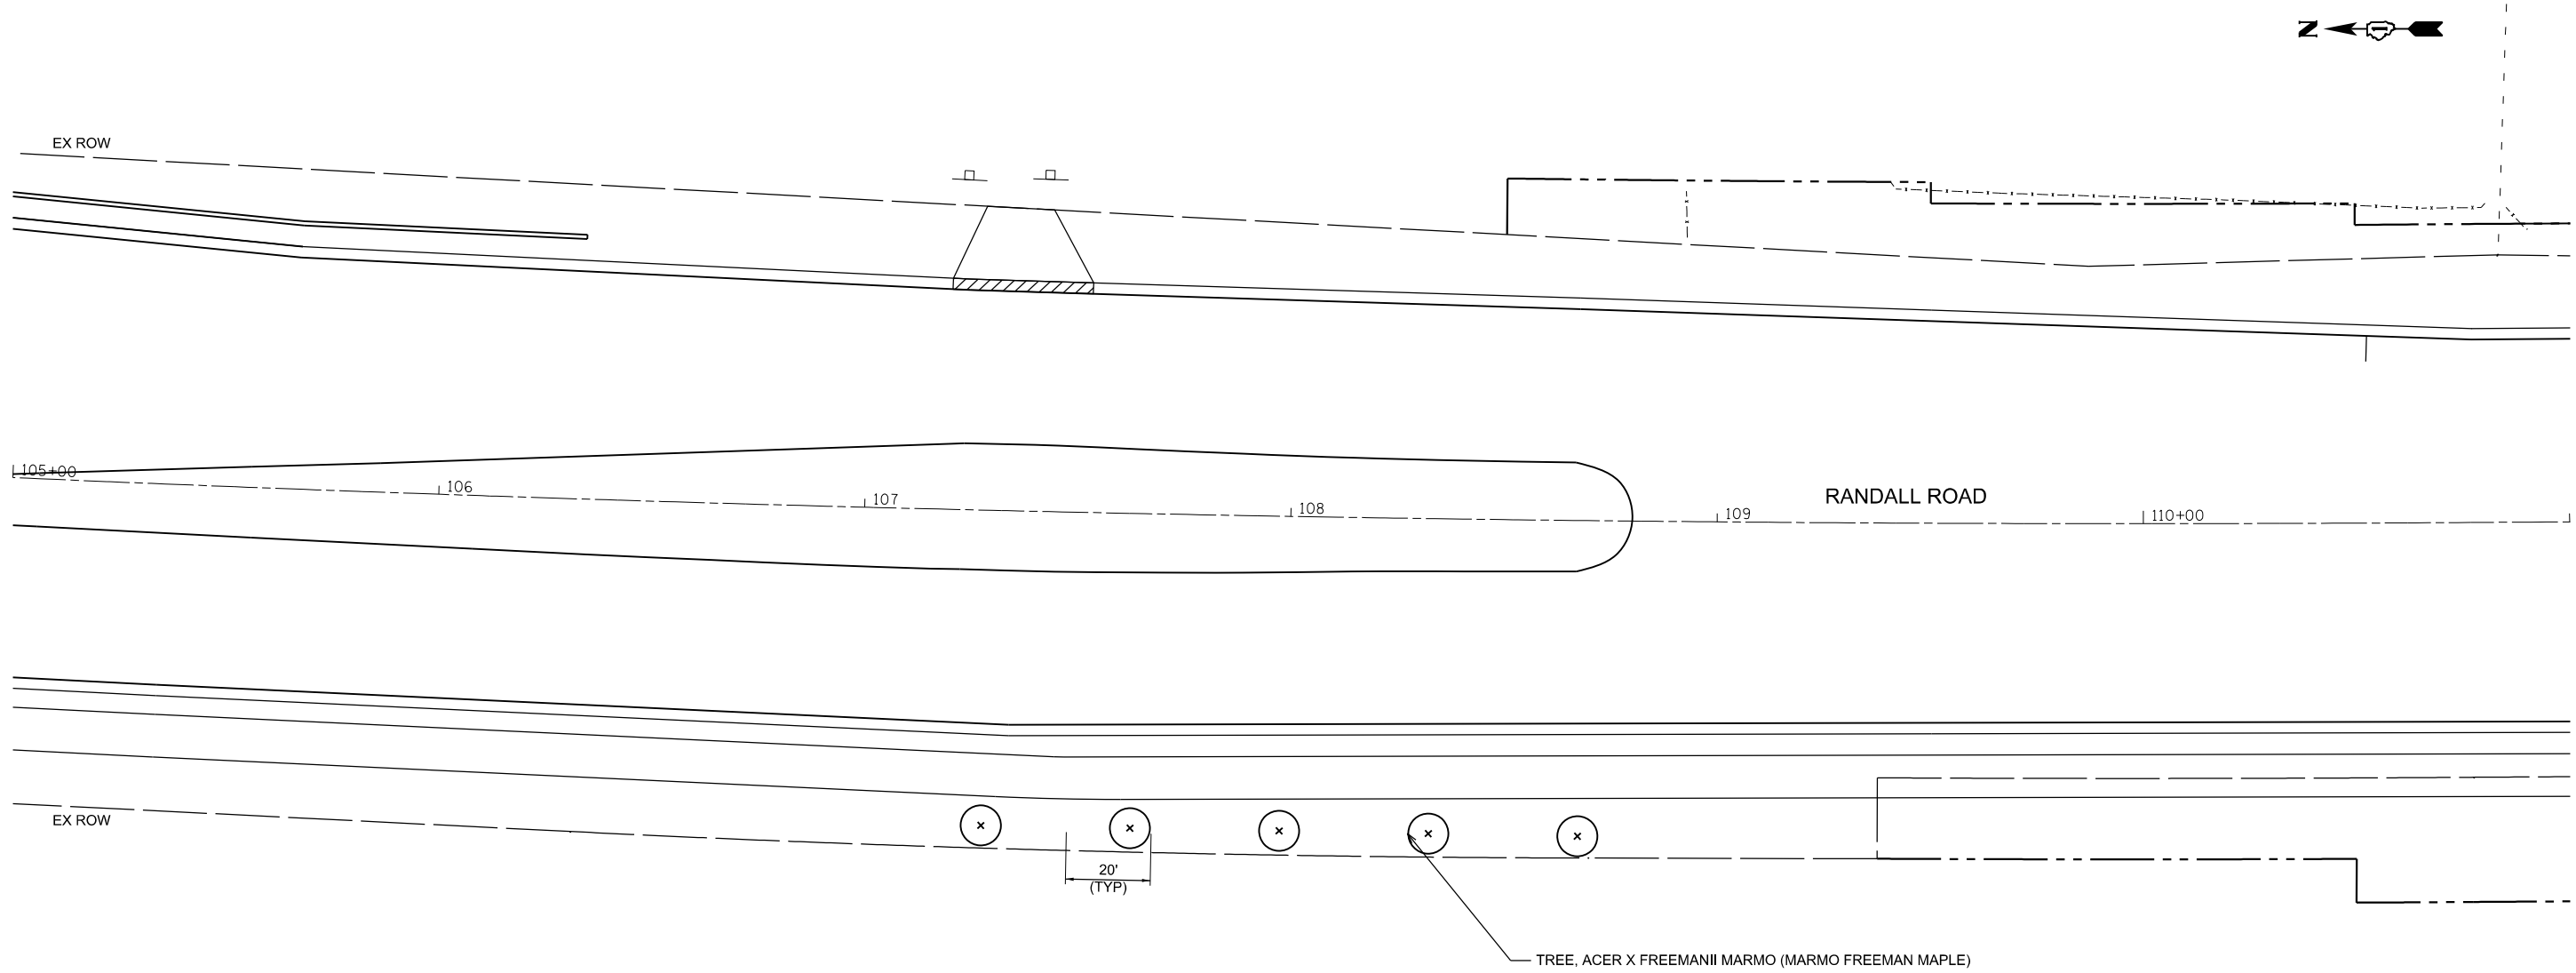

MODEL: Default
FILE NAME: W:\894-088 Randall at Higgins Phase II Engineering\CADD Sheets\014_Landscaping\Plan\19-00514-00-WR_Landscaping Notes.dgn


TREE PLANTING GENERAL NOTES

1. THE CONTRACTOR SHALL COORDINATE THE PLANTING, LANDSCAPING, AND RESTORATION WORK WITH WORK BY THE GRADING CONTRACTOR AND OTHER UTILITY CONTRACTORS. THE RESTORATION AND PLANTING WORK SHALL BE COMPLETED AS DIRECTED BY THE ENGINEER, NOTWITHSTANDING THE PLANTING RESTRICTIONS AS DESCRIBED IN THE STANDARD SPECIFICATIONS AND THE SPECIAL PROVISIONS.
2. ALL PLANT MATERIAL NOT PLANTED ACCORDING TO THE SPECIFIED SEASONAL DATE SHALL REQUIRE PRIOR WRITTEN APPROVAL FROM THE ENGINEER. FAILURE TO SECURE SUCH APPROVAL WILL RESULT IN THE REJECTION OF THE PLANT MATERIAL AND THE REPLACEMENTS SHALL BE AT NO ADDITIONAL COST TO THE CONTRACT.
3. ALL WORK SHALL BE IN ACCORDANCE WITH SECTIONS 253 AND 254 OF THE STANDARD SPECIFICATIONS, THE SPECIAL PROVISIONS, AND THE DETAILS SHOWN ON THE PLANS.
4. THE INTENT OF THE LANDSCAPING PLAN IS TO LOOK NATURAL AND PLEASANT. THE CONTACTOR SHALL GROUP THE TREES AND SHRUBS TO LOOK NATURAL IN A SOMEWHAT RANDOM ORDER.
5. THE CONTRACTOR SHALL BE CAREFUL WHEN PLANTING TREES AND SHRUBS NEAR AN INTERSECTION TO AVOID THE NECESSARY SIGHT TRIANGLE OF APPROACHING TRAFFIC. IF IN DOUBT, THE CONTRACTOR SHALL CONSULT WITH THE ENGINEER REGARDING CLEAR DISTANCE OF THE SIGHT TRIANGLE.
6. THE CONTRACTOR SHALL VERIFY THE LOCATIONS AND DEPTH OF ANY UNDERGROUND UTILITIES PRIOR TO EXCAVATION OR CONSTRUCTION.
7. THE CONTRACTOR SHALL FOLLOW THE PLANTING PLANS AND MAY ADJUST LOCATIONS TO FIT FIELD CONDITIONS BUT SHALL NOT INSTALL TREES DIRECTLY ABOVE ANY MAJOR DRAINAGE CULVERTS.
8. ADDITIONAL TREES NOT IN SCHEDULES, THE CONTRACTOR SHALL COORDINATE WITH THE ENGINEER ABOUT FINAL LOCATIONS OF ALL TREES.
9. THE CONTRACTOR SHALL SCHEDULE PLANT MATERIAL TO KEEP UP WITH THE PLANTING OPERATION. IF PLANTINGS ARE NOT PLANTED IMMEDIATELY AFTER DELIVERY TO THE JOB SITE, THE CONTRACTOR SHALL HARBOR THE PLANTINGS AS DESCRIBED IN ARTICLE 253.06 OF THE STANDARD SPECIFICATIONS FOR TEMPORARY STORAGE.

TREE BILL OF MATERIALS

ITEM NUMBER	ITEM NAME	SIZE	UNIT	QUANTITY
SHADE TREES				
A2000216	TREE, ACER X FREEMANII MARMO (MARMO FREEMAN MAPLE)	2" C	EACH	28
A2006600	TREE, QUERUS COCCINEA (SCARLET OAK)	1 3/4" C	EACH	27
A2007116	TREE, QUERCUS RUBRA (RED OAK)	2" C	EACH	27
A2007132	TREE, QUERCUS SCHEUTTI (SWAMP BUR OAK)	2" C	EACH	27
A2008468	TREE, ULMUS AMERICANA PRINCETON (PRINCETON AMERICAN ELM)	2" C	EACH	27

PLUG PLANTING DETAIL

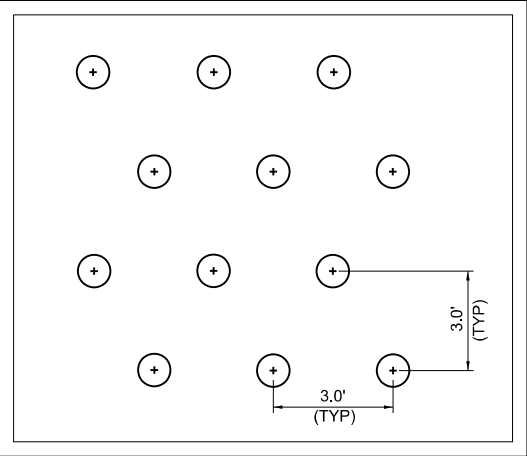

PLUG PLANTING NOTES

1. PLACEMENT OF PLUGS SHALL BE IN A RANDOM PATTERN AND SHALL BE 36" APART CENTER TO CENTER.
2. ALL PLUGS SHALL BE PLANTED WITHIN THE BOTTOM OF PROPOSED DETENTION BASINS.

TREE PLANTING SCHEDULE CONT.

ALIGNMENT	STATION	OFFSET	TREETYPE	QUANTITY
RECREATION	302+99.87	67.80 RT	TREE, ACER X FREEMANII MARMO (MARMO FREEMAN MAPLE)	1
RECREATION	303+29.86	67.75 RT	TREE, ACER X FREEMANII MARMO (MARMO FREEMAN MAPLE)	1
RECREATION	303+59.86	67.72 RT	TREE, ACER X FREEMANII MARMO (MARMO FREEMAN MAPLE)	1
RECREATION	303+89.86	67.69 RT	TREE, ACER X FREEMANII MARMO (MARMO FREEMAN MAPLE)	1
RECREATION	304+19.86	67.67 RT	TREE, ACER X FREEMANII MARMO (MARMO FREEMAN MAPLE)	1
RANDALL	88+26.45	72.60 LT	QUERCUS SCHEUTTI (SWAMP BUR OAK)	1
RANDALL	88+66.45	71.82 LT	QUERCUS SCHEUTTI (SWAMP BUR OAK)	1
RANDALL	89+06.43	70.82 LT	QUERCUS SCHEUTTI (SWAMP BUR OAK)	1
RANDALL	89+46.42	69.82 LT	QUERCUS SCHEUTTI (SWAMP BUR OAK)	1
RANDALL	89+86.40	69.08 LT	QUERCUS SCHEUTTI (SWAMP BUR OAK)	1
RANDALL	90+26.39	68.31 LT	QUERCUS SCHEUTTI (SWAMP BUR OAK)	1
RANDALL	90+66.38	67.31 LT	QUERCUS SCHEUTTI (SWAMP BUR OAK)	1
RANDALL	91+06.37	66.30 LT	QUERCUS SCHEUTTI (SWAMP BUR OAK)	1
RANDALL	91+46.37	65.26 LT	QUERCUS SCHEUTTI (SWAMP BUR OAK)	1
RANDALL	95+78.89	96.11 LT	TREE, ACER X FREEMANII MARMO (MARMO FREEMAN MAPLE)	1
RANDALL	95+85.41	216.48 LT	TREE, QUERUS COCCINEA (SCARLET OAK)	1
RANDALL	95+86.69	176.79 LT	TREE, ULMUS AMERICANA PRINCETON (PRINCETON AMERICAN ELM)	1
RANDALL	95+87.76	136.85 LT	QUERCUS SCHEUTTI (SWAMP BUR OAK)	1
RANDALL	96+10.63	245.95 LT	QUERCUS RUBRA (RED OAK)	1
RANDALL	96+19.22	97.24 LT	QUERCUS RUBRA (RED OAK)	1
RANDALL	96+27.22	177.65 LT	QUERCUS RUBRA (RED OAK)	1
RANDALL	96+28.15	137.70 LT	QUERCUS RUBRA (RED OAK)	1
RANDALL	96+49.70	257.84 LT	TREE, ULMUS AMERICANA PRINCETON (PRINCETON AMERICAN ELM)	1
RANDALL	96+69.53	98.67 LT	QUERCUS SCHEUTTI (SWAMP BUR OAK)	1
RANDALL	96+88.85	269.59 LT	TREE, QUERUS COCCINEA (SCARLET OAK)	1
RANDALL	97+09.89	99.43 LT	TREE, QUERUS COCCINEA (SCARLET OAK)	1
RANDALL	97+50.24	100.09 LT	TREE, ULMUS AMERICANA PRINCETON (PRINCETON AMERICAN ELM)	1
RANDALL	97+90.55	100.63 LT	QUERCUS RUBRA (RED OAK)	1
RANDALL	98+05.93	304.10 LT	QUERCUS RUBRA (RED OAK)	1
RANDALL	98+30.48	101.14 LT	QUERCUS RUBRA (RED OAK)	1
RANDALL	98+30.57	141.38 LT	TREE, ULMUS AMERICANA PRINCETON (PRINCETON AMERICAN ELM)	1
RANDALL	98+44.26	315.54 LT	QUERCUS SCHEUTTI (SWAMP BUR OAK)	1
RANDALL	98+69.68	161.68 LT	QUERCUS SCHEUTTI (SWAMP BUR OAK)	1
RANDALL	98+70.18	121.68 LT	TREE, QUERUS COCCINEA (SCARLET OAK)	1
RANDALL	98+82.62	326.90 LT	QUERCUS RUBRA (RED OAK)	1
RANDALL	99+07.77	303.07 LT	TREE, QUERUS COCCINEA (SCARLET OAK)	1
RANDALL	99+09.18	202.13 LT	TREE, ULMUS AMERICANA PRINCETON (PRINCETON AMERICAN ELM)	1
RANDALL	99+09.67	162.18 LT	TREE, QUERUS COCCINEA (SCARLET OAK)	1
RANDALL	107+28.98	73.94 RT	TREE, ACER X FREEMANII MARMO (MARMO FREEMAN MAPLE)	1
RANDALL	107+63.73	73.81 RT	TREE, ACER X FREEMANII MARMO (MARMO FREEMAN MAPLE)	1
RANDALL	107+98.51	73.79 RT	TREE, ACER X FREEMANII MARMO (MARMO FREEMAN MAPLE)	1
RANDALL	108+33.28	73.87 RT	TREE, ACER X FREEMANII MARMO (MARMO FREEMAN MAPLE)	1
RANDALL	108+68.06	74.06 RT	TREE, ACER X FREEMANII MARMO (MARMO FREEMAN MAPLE)	1
TOTAL				43



BLA, Inc.

USER NAME = cesario	DESIGNED - TN	REVISED -
	DRAWN - TN	REVISED -
PLOT SCALE = 48.0000' / in.	CHECKED - GJE	REVISED -
PLOT DATE = 6/19/2025	DATE - 02/15/2025	REVISED -

STATE OF ILLINOIS
DEPARTMENT OF TRANSPORTATION

RANDALL ROAD AT IL ROUTE 72 (HIGGINS ROAD)
LANDSCAPING NOTES AND SCHEDULE

SCALE: SHEET 8 OF 9 SHEETS STA. TO STA.

F.A.P. RTE. 0336	SECTION 19-00514-00-WR	COUNTY KANE	TOTAL SHEETS 304	SHEET NO. 152
CONTRACT NO. 61L28				
ILLINOIS FED. AID PROJECT				

MODEL: Default
FILE NAME: V:\894-088 Randall at Higgins Phase II Engineering\CADD Sheets\014_Landscaping\Plan\19-00514-00-0VR_Landscaping Notes.dgn



BLA, Inc.


USER NAME = cesario	DESIGNED - TN	REVISED -
	DRAWN - TN	REVISED -
PLOT SCALE = 48.0000' / 1"	CHECKED - GJE	REVISED -
PLOT DATE = 6/19/2025	DATE - 02/15/2025	REVISED -

**STATE OF ILLINOIS
DEPARTMENT OF TRANSPORTATION**


**RANDALL ROAD AT IL ROUTE 72 (HIGGINS ROAD)
LANDSCAPING DETAILS**

SCALE: SHEET 9 OF 9 SHEETS STA. TO STA.

F.A.P. RTE.	SECTION	COUNTY	TOTAL SHEETS	SHEET NO.
0336	19-00514-00-WR	KANE	304	153
CONTRACT NO. 61L28				
ILLINOIS FED. AID PROJECT				

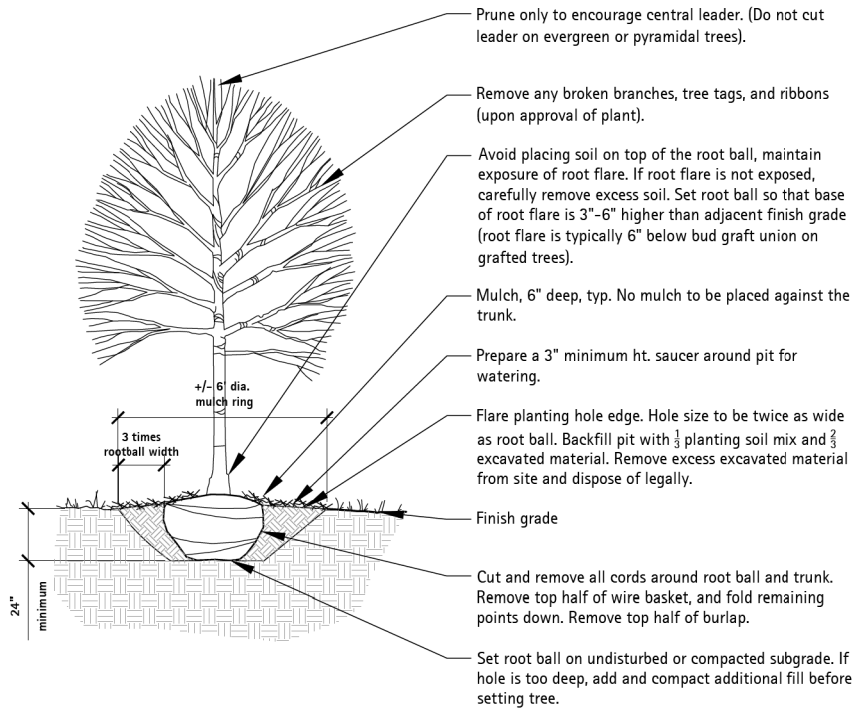

Section - Shade Tree Planting

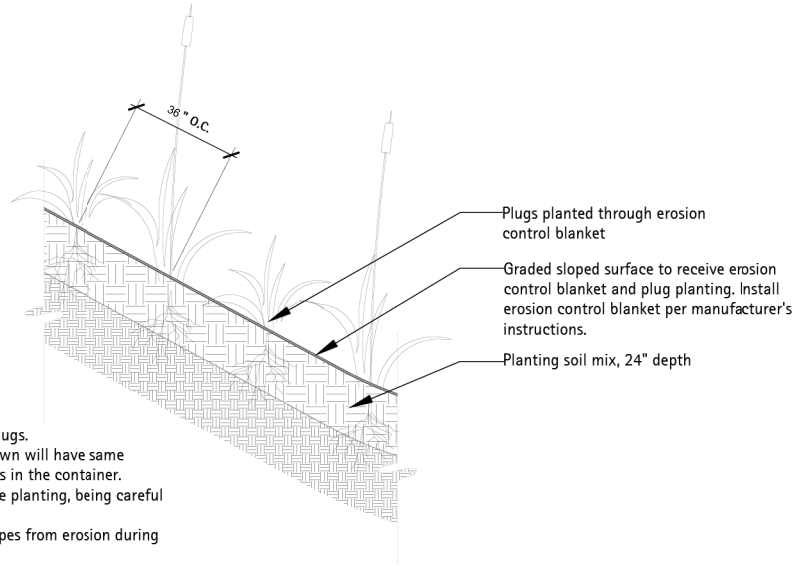

- Notes:
1. Use triangular spacing for all plugs.
 2. Set individual plugs so that crown will have same relationship to finished grade as in the container.
 3. Remove plastic container before planting, being careful to keep root system intact.
 4. Take precautions to protect slopes from erosion during construction activities.

Section - Plug Planting Detail

(NOT TO SCALE)

MODEL: Default
FILE NAME: pw:\IL084EBIDINTEG.Illinois.gov\PW\DOT\Documents\DOT Offices\District 1\Projects\Dist5td22x34\CADData\CADsheets\ts05.dgn

EACH PAIR OF LOOP WIRES SHALL BE PLACED IN A SEPARATE EMPTY COILABLE NONMETALLIC CONDUIT FROM THE EDGE OF PAVEMENT TO THE HANDHOLE. SPACING BETWEEN THE HOLES DRILLED IN THE PAVEMENT SHALL NOT BE LESS THAN 6" (150 mm). EMPTY COILABLE NONMETALLIC CONDUIT SHALL BE INCLUDED IN THE COST OF THE LOOP WIRE.

THE NUMBER OF LOOP TURNS SHALL BE AS RECOMMENDED BY THE AMPLIFIER MANUFACTURER. ALL ADJACENT SIDES OF THE LOOPS SHALL BE INSTALLED IN SUCH A WAY THAT THE CURRENT FLOW IS IN THE SAME DIRECTION TO REINFORCE ITS MAGNETIC FIELDS FOR SMALL VEHICLE DETECTION.

EACH LOOP LEAD-IN SHALL BE IDENTIFIED AND PERMANENTLY TAGGED IN THE HANDHOLE. EACH LEAD-IN CABLE TAG SHALL INDICATE THE LOCATION OF THE LOOP, LOOP ROTATION (CLOCKWISE/COUNTERCLOCKWISE), LOOP LEAD-IN DIRECTION (IN OR OUT), LOOP CABLE NUMBER AND LOCATION IN CABINET, AND NUMBER OF TURNS IN THE DETECTOR LOOPS IN WATER PROOF INK AS INDICATED ON THE DISTRICT 1 STANDARD TRAFFIC SIGNAL DESIGN DETAIL. THE CONTRACTOR SHALL MARK LOOP LOCATIONS ON RECORD DRAWINGS AND PRESENT TO THE ENGINEER AFTER FINAL INSPECTION. LOOPS SHALL BE MARKED BY LANE AND LOOP NUMBER. SEE DETAIL BELOW.

ALL LOOP CABLE SHALL BE FASTENED WITH PLASTIC TIE WRAP TO THE HANDHOLE HOOKS.

IN ASPHALT PAVEMENT, LOOPS SHOULD BE PLACED IN THE BINDER AND DIVEHOLES MARKED AT THE CURB WITH A SAW-CUT. THE SAW-CUT SHALL BE CUT IN ACCORDANCE WITH LOCAL AND E.P.A. DUST CONTROL REQUIREMENTS. DETECTOR LOOP(S) SHALL NOT BE INSTALLED IN WET CONDITIONS AND THE SAW-CUTS MUST BE FREE OF DEBRIS AND RESIDUE SUCH AS DUST AND WATER WHICH IS TO BE ACHIEVED BY THE USE OF COMPRESSED AIR, WIRE BRUSHING AND HEAT DRYING ACCORDING TO SEALANT MANUFACTURER REQUIREMENTS. THE DETECTOR WIRE SHALL BE HELD IN PLACE BY THE USE OF FORM WEDGES. WEDGES SHALL BE SPACED NO MORE THAN 18" (450 mm) APART.

LOOP SPLICES SHALL BE SOLDERED USING A SOLDERING IRON. BLOW TORCHES OR OTHER DEVICES WHICH OXIDIZE COPPER CABLE SHALL NOT BE ALLOWED FOR SOLDERING OPERATIONS. SEE DETAIL BELOW RIGHT.


PREFORMED DETECTOR LOOPS SHALL BE USED, AS SHOWN ON THE PLANS, WHERE NEW CONCRETE PAVEMENT IS PROPOSED. THE INSTALLATION OF PREFORMED LOOPS SHALL BE IN ACCORDANCE WITH THE DISTRICT 1 SPECIFICATIONS OR AS DIRECTED BY THE ENGINEER.

Diagram illustrating a loop structure with two ports (left and right) and three labels:


- LANE (A) LOOP (B)
- LOOP DIRECTION (C)
- LOOP ROTATION (D)

-
- Diagram illustrating the wiring configuration for a loop detector system, showing three loops (Loop 1, Loop 2, Loop 3) connected to a central unit and an amplifier.
- Labels and components shown:
- VEHICLE MOVEMENT
 - LOOP 3
 - LOOP 2
 - LOOP 1
 - STRANDED LOOP WIRE NO. 14 1/C IN EMPTY COILABLE NONMETALLIC CONDUIT [5 TWISTS/FT(MM)]
 - LOOP TAG
 - HANDHOLE OR JUNCTION BOX
 - LOOP-TO-LOOP SPLICE (SEE DETAIL "A")
 - LOOP DETECTOR SPLICE (SEE DETAIL "B")
 - NO. 14 2/C TWISTED, SHIELDED LEAD-IN
 - CONTROLLER CABINET
 - AMPLIFIER
 - OUTPUT
- NOTE: LOOP POLARITY AS SHOWN MUST BE STRICTLY OBSERVED WHEN SPLICING LOOP WIRES TO THE NO. 14 2/C TWISTED, SHIELDED LEAD-IN.

- LOOPS SHALL BE SPICED IN SERIES.
SAW-CUTS SHALL BE A MINIMUM WIDTH OF 5/16" (8 mm).
- SAW-CUT DEPTHS SHALL BE 3" (75 mm). IF IN CONCRETE,
- THE SAW-CUT DEPTH SHALL BE TO THE TOP OF THE REINFORCEMENT.
- LOOP CORNERS SHALL BE DRILLED WITH A 2" (50 mm) DIAMETER CORE.

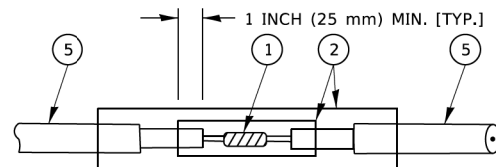

DETAIL "A"
LOOP-TO-LOOP SPLICE

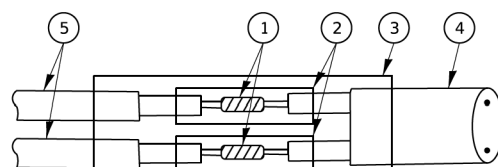


DETAIL "B"

LOOP-TO-CONTROLLER SPLICE

The diagram illustrates the 36 to 60 inch cable assembly. It shows a cable with three conductors (labeled 1, 2, and 3) and a shield (labeled 5). The cable is terminated with a connector (labeled 6 and 7) on one end and a plug (labeled 6 and 7) on the other. Dimensions are provided for the cable length (36" TO 60" / 900 mm TO 1500mm) and the plug length (1" (25mm) MIN. (TYP)).

DETAIL "A"
LOOP-TO-LOOP SPLICE

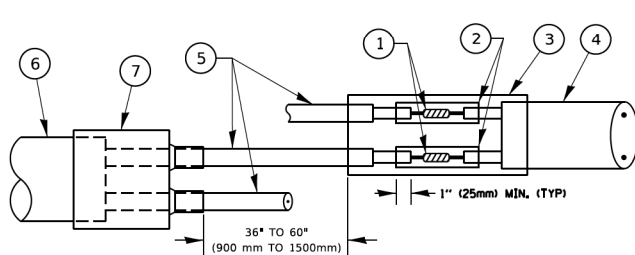

DETAIL "B"

LOOP-TO-CONTROLLER SPLICE

LOOP DETECTOR SPLICE


- | | |
|---|--|
| <p>① WESTERN UNION SPLICE SOLDERED WITH ROSIN CORE FLUX. ALL EXPOSED SURFACES OF THE SOLDER SHALL BE SMOOTH. THE WESTERN UNION SPLICES SHALL BE STAGGERED.</p> <p>② WCSMW 30/100 HEAT SHRINK TUBE, MINIMUM LENGTH 3" (75 mm), UNDERWATER GRADE.</p> <p>③ WCS 200/750 HEAT SHRINK TUBE, MINIMUM LENGTH 6" (150 mm), UNDERWATER GRADE.</p> <p>④ NO. 14 2/C TWISTED, SHIELDED CABLE.</p> | <p>⑤ LOOP CONDUCTOR WITH FLEXIBLE PLASTIC TUBE. PRE-FORMED LOOP</p> <p>⑥ XL POLYOLEFIN 2 CONDUCTOR</p> <p>⑦ BREAKOUT SEALS. TYCO CBR-2 OR APPROVED EQUAL</p> |
|---|--|

	USER NAME = footermj	DESIGNED -	REVISED -	STATE OF ILLINOIS DEPARTMENT OF TRANSPORTATION	DISTRICT ONE STANDARD TRAFFIC SIGNAL DESIGN DETAILS					F.A. RTE.	SECTION	COUNTY	TOTAL SHEETS	SHEET NO.
	PLOT SCALE = 50,0000 ' / in.	DRAWN -	REVISED -								19-00514-00-WR	KANE	304	155
	PLOT DATE = 3/4/2019	CHECKED -	REVISED -		TS-05					CONTRACT NO. 61L28				
		DATE -	REVISED -							SCALE: NONE	SHEET 2 OF 7 SHEETS	STA. N/A TO STA. N/A	ILLINOIS FED. AID PROJECT	

MODEL Default
FILE Name: p:\w\0848\BENTEC\Illinois.gov\PHWDOT\Documents\DOT Offices\District 1\Projects\Dist5\0223\21CADData\CAD\sheetst05.dgn

TRAFFIC SIGNAL MAST ARM AND SIGNAL POST


MAST ARM MOUNTED SIGNALS IN EXISTING, PROPOSED OR FUTURE SIDEWALK/BICYCLE PATH AREA. INTERSECTION SHOWN WITH PEDESTRIAN SIGNALS AND PEDESTRIAN PUSHBUTTON DETECTORS.

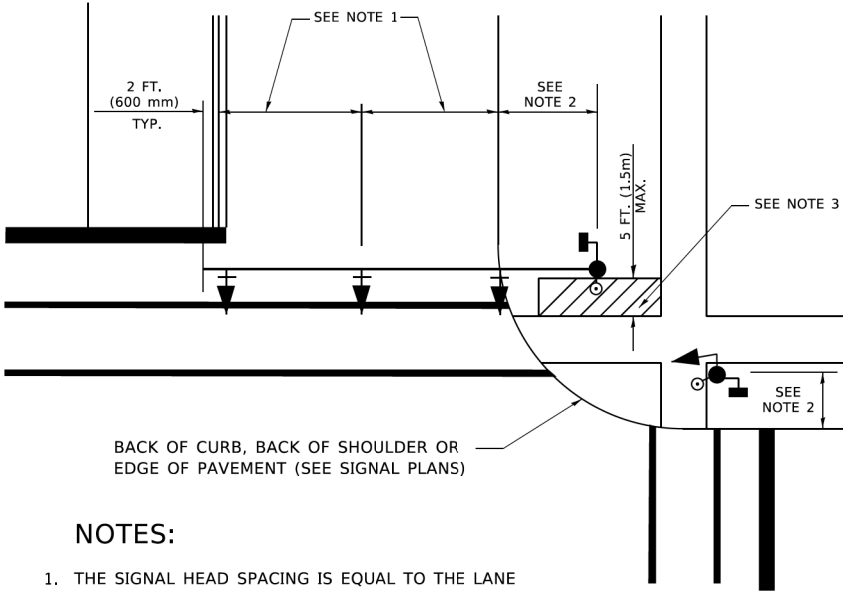

NOTES:

1. THE SIGNAL HEAD SPACING IS EQUAL TO THE LANE WIDTH OR AS SHOWN ON THE TRAFFIC SIGNAL PLAN.
2. REFER TO THE TRAFFIC SIGNAL EQUIPMENT OFFSET TABLE.
3. PROVIDE A LEVEL ALL-WEATHER SURFACE (CONCRETE SIDEWALK, ASPHALT BICYCLE PATH SURFACE OR MATCHING MATERIAL TO THE ADJACENT SURFACE) UP TO THE MAST ARM SHAFT OR THE SIGNAL POST.
4. THE FACE OF THE PEDESTRIAN PUSHBUTTON SHALL BE PARALLEL TO THE CROSSWALK TO BE USED.
5. THE LOCATIONS AND INSTALLATION OF PEDESTRIAN SIGNAL HEADS AND PEDESTRIAN PUSHBUTTONS SHALL MEET THE REQUIREMENTS OF THE MUTCD AND INFORMATION FOUND IN THE "AMERICANS WITH DISABILITIES ACT ACCESSIBILITY GUIDELINES FOR BUILDINGS AND FACILITIES."


PEDESTRIAN SIGNAL POST AND PEDESTRIAN PUSH BUTTON POST

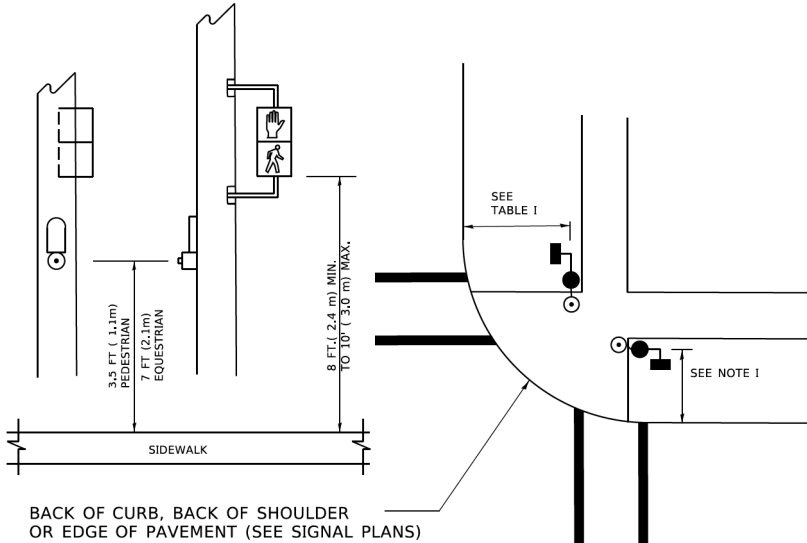

NOTES:

1. REFER TO THE TRAFFIC SIGNAL EQUIPMENT OFFSET TABLE.
2. PROVIDE A LEVEL ALL-WEATHER SURFACE (CONCRETE SIDEWALK, ASPHALT BICYCLE PATH SURFACE OR MATCHING MATERIAL TO THE ADJACENT SURFACE) UP TO THE PEDESTRIAN SIGNAL POST OR THE PEDESTRIAN PUSH BUTTON POST.
3. THE FACE OF THE PEDESTRIAN PUSHBUTTON SHALL BE PARALLEL TO THE CROSSWALK TO BE USED.
4. THE LOCATIONS AND INSTALLATION OF PEDESTRIAN SIGNAL HEADS AND PEDESTRIAN PUSHBUTTONS SHALL MEET THE REQUIREMENTS OF THE MUTCD AND INFORMATION FOUND IN THE "AMERICANS WITH DISABILITIES ACT ACCESSIBILITY GUIDELINES FOR BUILDINGS AND FACILITIES."

RECOMMENDED PUSHBUTTON LOCATIONS

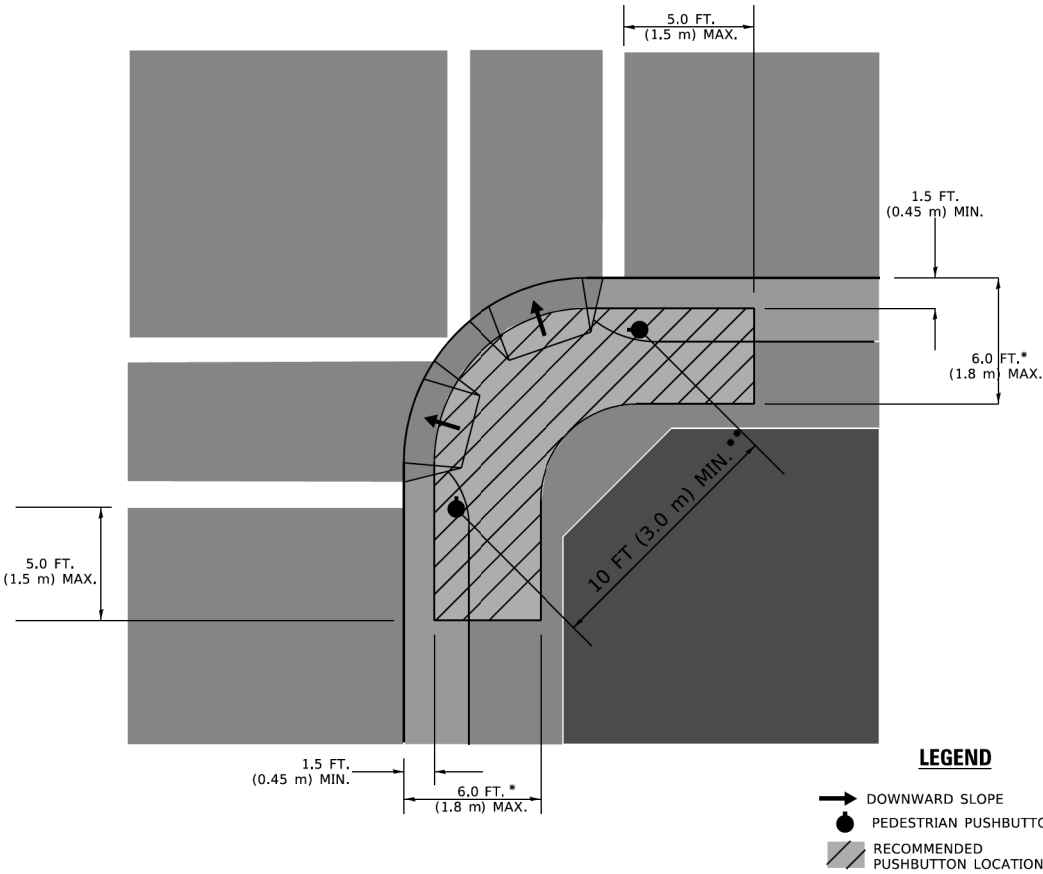

LEGEND

- DOWNWARD SLOPE
- PEDESTRIAN PUSHBUTTON
- RECOMMENDED PUSHBUTTON LOCATIONS

- * WHERE THERE ARE CONSTRAINTS THAT MAKE IT IMPRACTICAL TO PLACE THE PEDESTRIAN PUSHBUTTON BETWEEN 1.5 FT (0.45 m) AND 6 FT (1.8 m) FROM THE EDGE OF THE CURB, SHOULDER, OR PAVEMENT, IT SHOULD NOT BE FURTHER THAN 10 FT (3 m) FROM THE EDGE OF CURB, SHOULDER, OR PAVEMENT.
- ** WHERE THERE ARE CONSTRAINTS ON A PARTICULAR CORNER THAT MAKE IT IMPRACTICAL TO PROVIDE THE 10 FT (3 m) SEPERATION BETWEEN THE TWO PEDESTRIAN PUSHBUTTONS, THE PUSHBUTTONS MAY BE PLACED CLOSER TOGETHER OR ON THE SAME POLE.

NOTES:

1. PEDESTRIAN SIGNAL HEADS SHALL BE MOUNTED WITH THE BOTTOM OF THE SIGNAL HOUSING INCLUDING BRACKETS NOT LESS THAN 8 FT (2.4 m) OR MORE THAN 10 FT (3 m) ABOVE SIDEWALK LEVEL, AND SHALL BE POSITIONED AND ADJUSTED TO PROVIDE MAXIMUM VISIBILITY AT THE BEGINNING OF THE CONTROLLED CROSSWALK.
2. THE BOTTOM OF THE SIGNAL HOUSING (INCLUDING BRACKETS) OF A VEHICULAR SIGNAL FACE THAT IS NOT LOCATED OVER A HIGHWAY SHALL BE AT LEAST 8 FT (2.4 m) BUT NOT MORE THAN 19 FT (5.8 m) ABOVE THE SIDEWALK OR, IF THERE IS NO SIDEWALK, ABOVE THE PAVEMENT GRADE AT THE CENTER OF THE ROADWAY.
3. THE BOTTOM OF THE SIGNAL HOUSING AND ANY RELATED ATTACHMENTS TO A SIGNAL FACE LOCATED OVER ANY PORTION OF A HIGHWAY SHALL BE ACCORDING TO CURRENT STATE STANDARDS 877001, 877002, 877006, 877011 AND 877012 WITH A MINIMUM OF 16 FT (5.0 m) AND A MAXIMUM OF 18 FT. (5.5 m) FROM THE HIGHEST POINT OF PAVEMENT.
4. THE BOTTOM OF THE TEMPORARY SPAN WIRE MOUNTED SIGNAL HOUSING AND ANY RELATED ATTACHMENTS TO A SIGNAL FACE LOCATED OVER ANY PORTION OF A HIGHWAY SHALL BE ACCORDING TO CURRENT STATE STANDARD 880001 WITH A MINIMUM OF 17 FT (5.18 m) FROM THE HIGHEST POINT OF PAVEMENT.
5. THE TOP OF THE SIGNAL HOUSING OF A SIGNAL FACE LOCATED OVER ANY PORTION OF A HIGHWAY SHALL NOT BE MORE THAN 25.6 FT (7.8 m) ABOVE THE PAVEMENT.



TRAFFIC SIGNAL EQUIPMENT OFFSET

TRAFFIC SIGNAL EQUIPMENT	COMBINATION CONCRETE CURB AND GUTTER (MINIMUM DISTANCE FROM BACK OF CURB TO CENTERLINE OF FOUNDATION)	SHOULDER/NON-CURBED AREA (MINIMUM DISTANCE FROM EDGE OF PAVEMENT TO CENTERLINE OF FOUNDATION)
TRAFFIC SIGNAL MAST ARM POLE	6 FT (1.8m)	SHOULDER WIDTH + 2 FT (0.5m), MINIMUM 10 FT (3.0m)
TRAFFIC SIGNAL POST	4 FT (1.2m)	SHOULDER WIDTH + 2 FT (0.5m), MINIMUM 10 FT (3.0m)
PEDESTRIAN SIGNAL POST	4 FT (1.2m)	SHOULDER WIDTH + 2 FT (0.5m), MINIMUM 10 FT (3.0m)
PEDESTRIAN PUSHBUTTON POST	4 FT (1.2m)	SHOULDER WIDTH + 2 FT (0.5m), MINIMUM 10 FT (3.0m)
TEMPORARY WOOD POLE	6 FT (1.8m)	SHOULDER WIDTH + 2 FT (0.5m), MINIMUM 10 FT (3.0m)
CONTROLLER CABINET	6 FT (1.8m) MINIMUM DISTANCE SEE NOTE 2	SHOULDER WIDTH + 6 FT (1.8m), MINIMUM 16 FT (4.9m) SEE NOTE 3.
SERVICE INSTALLATION, GROUND MOUNT	6 FT (1.8m) MINIMUM DISTANCE SEE NOTE 2	SHOULDER WIDTH + 6 FT (1.8m), MINIMUM 16 FT (4.9m) SEE NOTE 3.



NOTES:

1. CONTACT THE "AREA TRAFFIC SIGNAL MAINTENANCE AND OPERATIONS ENGINEER" FOR ASSISTANCE IN LOCATING THE TRAFFIC SIGNAL EQUIPMENT WHEN THERE ARE CONFLICTS WITH DITCHES OR THE MINIMUM OFFSET DISTANCES CANNOT BE MET.
2. MINIMUM DISTANCE FROM THE BACK OF CURB TO THE ROADWAY SIDE OF THE FOUNDATION.
3. MINIMUM DISTANCE FROM THE EDGE OF PAVEMENT TOTHE ROADWAY SIDE OF THE FOUNDATION.
4. ANY CHANGES TO THE OFFSETS OF THE FOUNDATIONS, FROM THE MINIMUM DISTANCES LISTED IN THE "TRAFFIC SIGNAL EQUIPMENT OFFSET" CHART AND THE TRAFFIC SIGNAL INSTALLATION PLAN, COULD EFFECT THE PLACEMENT OF THE SIGNAL HEADS, PEDESTRIAN SIGNAL HEADS AND THE PEDESTRIAN PUSHBUTTONS. THE SIGNAL HEAD PLACEMENT ON THE MAST ARMS SHALL REMAIN AS PER THE TRAFFIC SIGNAL INSTALLATION PLAN AND THE "TRAFFIC SIGNAL MAST ARM AND SIGNAL POST" DETAIL ABOVE. THE PROPOSED MAST ARM LENGTHS MAY NEED TO BE REVISED TO MEET THE ABOVE REQUIREMENTS. THE PEDESTRIAN SIGNAL HEADS AND PEDESTRIAN PUSHBUTTONS MUST MEET THE REQUIREMENTS UNDER THE DETAILS ON THIS SHEET.


USER NAME = footem]	DESIGNED -	REVISED -	STATE OF ILLINOIS DEPARTMENT OF TRANSPORTATION	DISTRICT ONE STANDARD TRAFFIC SIGNAL DESIGN DETAILS					F.A. RTE.	SECTION	COUNTY	TOTAL SHEETS	SHEET NO.
	DRAWN -	REVISED -								19-00514-00-WR	KANE	304	156
PLOT SCALE = 50.0000 ' / in.	CHECKED -	REVISED -							TS-05		CONTRACT NO. 61L28		
PLOT DATE = 3/4/2019	DATE -	REVISED -		SCALE: NONE SHEET 3 OF 7 SHEETS STA. N/A TO STA. N/A					ILLINOIS FED. AID PROJECT				

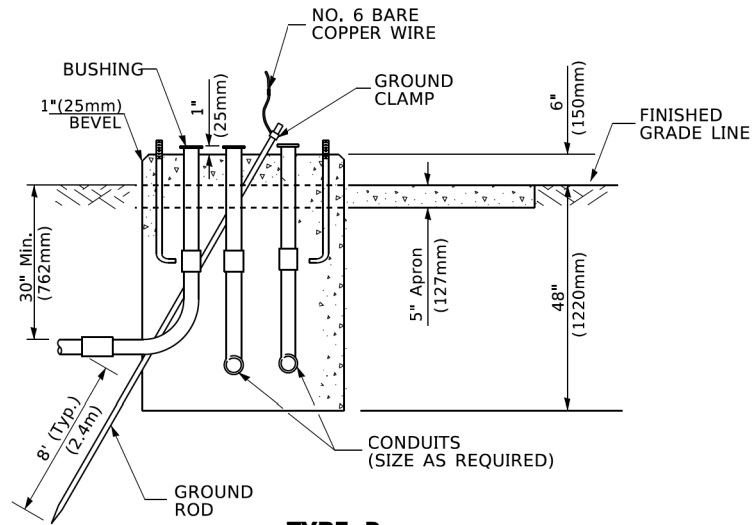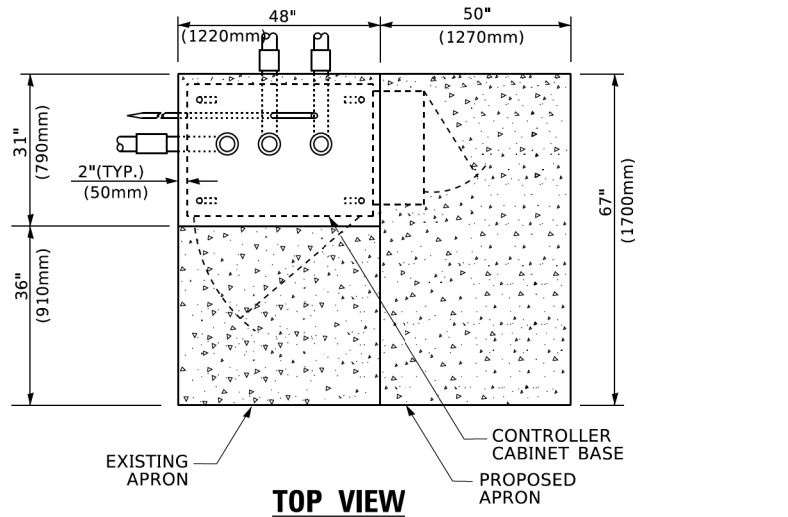

TYPE D
FOR GROUND MOUNTED
CONTROLLER CABINET
AND UPS BATTERY CABINET

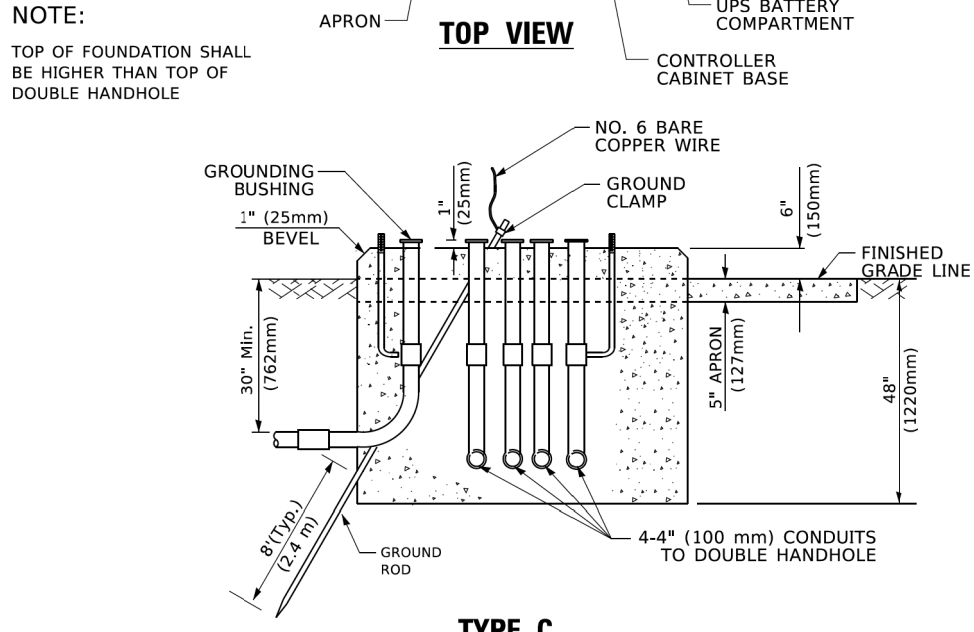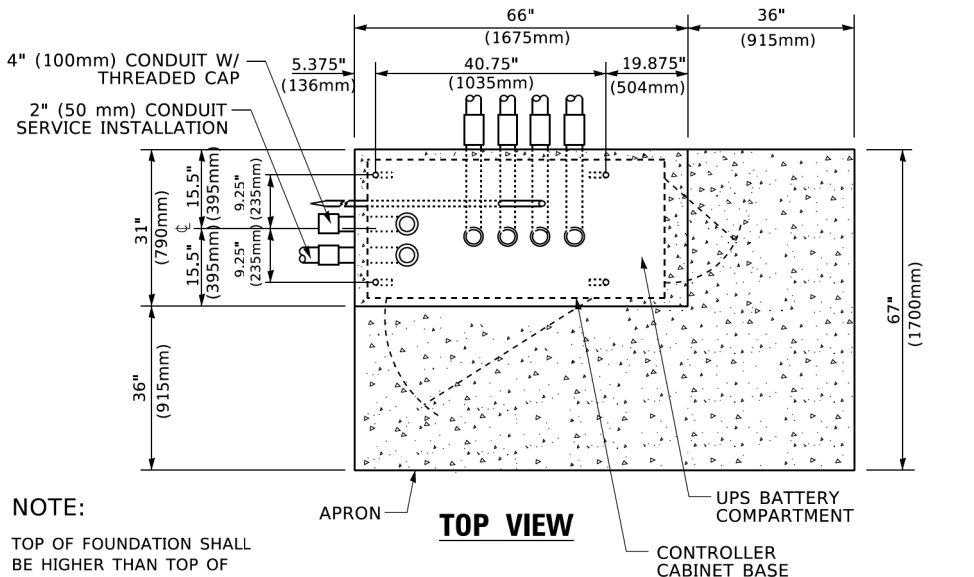

TYPE C
FOR GROUND MOUNTED
SUPER P (TYPE IV) AND SUPER R (TYPE V)
CONTROLLER CABINETS

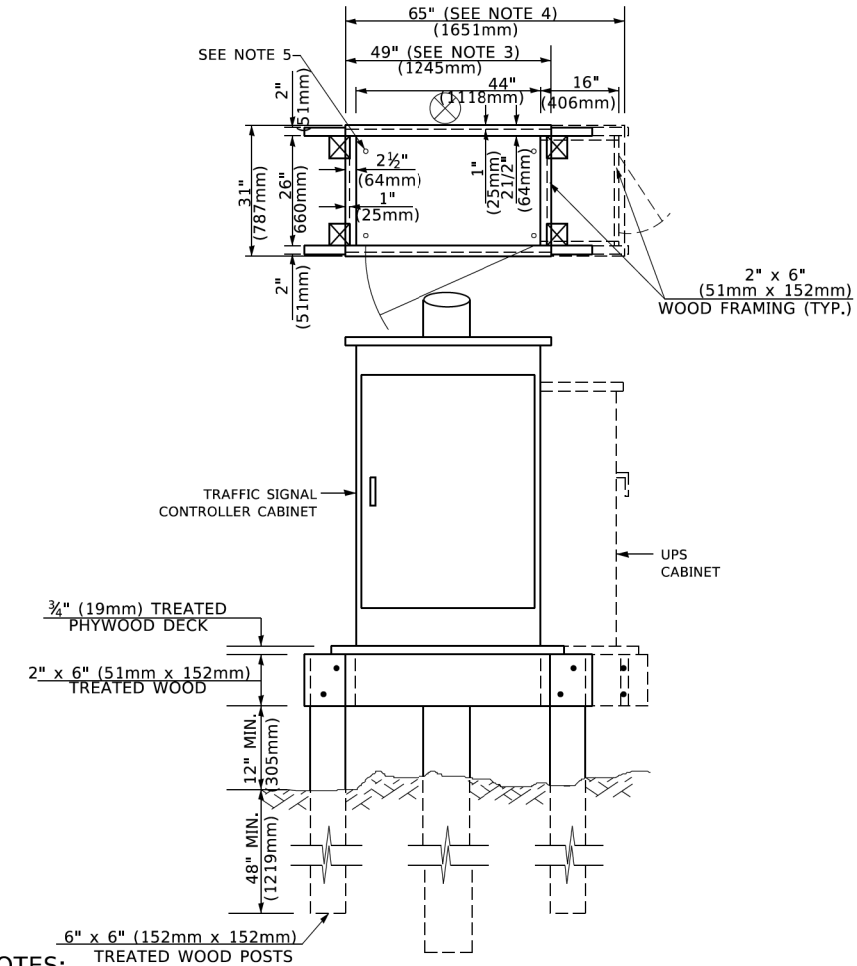

- NOTES:**
1. BASED ON CONTROLLER CABINET TYPE IV WITH BASE DIMENSIONS OF 26" x 44" (660mm x 1118mm). ADJUST PLATFORM SIZE TO FIT CABINET BASE DIMENSIONS BEING SUPPLIED.
 2. BASED ON UNINTERRUPTIBLE POWER SUPPLY CABINET WITH BASE DIMENSIONS OF 16" x 25" (406mm x 635mm). ADJUST PLATFORM SIZE TO FIT CABINET BASE DIMENSIONS BEING SUPPLIED.
 3. PLATFORM SIZE FOR CONTROLLER CABINET TYPE IV.
 4. PLATFORM SIZE FOR CONTROLLER CABINET TYPE IV AND UNINTERRUPTIBLE POWER SUPPLY CABINET.
 5. DRILLED HOLES THROUGH THE PLATFORM BASE TO MATCH THE CONTROLLER CABINET BOLT TEMPLATE. FASTEN THE CONTROLLER CABINET TO THE PLATFORM WITH CARRIAGE BOLTS, WASHERS AND NUTS.
 6. FASTEN ALL SUPPORT WOOD FRAMING TO THE WOOD POSTS WITH 2 LAG SCREWS FOR EACH CONNECTION..

TEMPORARY SIGNAL CONTROLLER
WOOD SUPPORT PLATFORM

CABLE SLACK LENGTH	FEET	METER
HANDHOLE	6.5	2.0
DOUBLE HANDHOLE	13.0	4.0
SIGNAL POST	2.0	0.6
MAST ARM	2.0	0.6
CONTROLLER CABINET	1.5	0.5
FIBER OPTIC AT CABINET	13.0	4.0
ELECTRIC SERVICE AT (CABINET OR SERVICE LOCATION)	1.5	0.5
GROUND CABLE (SIGNAL POST, MAST ARM, CABINET)	1.5	0.5
GROUND CABLE (BETWEEN FRAME AND COVER)	5.0	1.6

CABLE SLACK

VERTICAL CABLE LENGTH	FEET	METER
MAST ARM POLE (MAST ARM MOUNTED SIGNAL HEAD)		
(L = MAST ARM LENGTH - DISTANCE TO SIGNAL HEAD FROM END OF ARM)	20.0+L	6.0+L
BRACKET MOUNTED (MAST ARM POLE OR SIGNAL POLE)	13.0	4.0
PEDESTRIAN PUSH BUTTON	6.0	2.0
SERVICE INSTALLATION POLE MOUNT TO SERVICE DROP	13.5	4.1
SERVICE INSTALLATION POLE MOUNT TO GROUND	13.5	4.1
SERVICE INSTALLATION GROUND MOUNT	6.0	2.0
FOUNDATION (SIGNAL POST, MAST ARM POLE, CONTROLLER CABINET, SERVICE-GROUND MOUNT)	3.0	1.0

VERTICAL CABLE LENGTH

FOUNDATION	DEPTH
TYPE A - Signal Post	4'-0" (1.2m)
TYPE C - CONTROLLER W/ UPS	4'-0" (1.2m)
TYPE D - CONTROLLER	4'-0" (1.2m)
SERVICE INSTALLATION, GROUND MOUNT, TYPE A - SQUARE	4'-0" (1.2m)

DEPTH OF FOUNDATION

Most Arm Length	① Foundation Depth	Foundation Diameter	Spiral Diameter	Quantity of Rebars	Size of Rebars
Less than 30' (9.1 m)	10'-0" (3.0 m)	30" (750mm)	24" (600mm)	8	6(19)
Greater than or equal to 30' (9.1 m) and less than 40' (12.2 m)	13'-6" (4.1 m)	30" (750mm)	24" (600mm)	8	6(19)
	11'-0" (3.4 m)	36" (900mm)	30" (750mm)	12	7(22)
Greater than or equal to 40' (12.2 m) and less than 50' (15.2 m)	13'-0" (4.0 m)	36" (900mm)	30" (750mm)	12	7(22)
Greater than or equal to 50' (15.2 m) and up to 55' (16.8 m)	15'-0" (4.6 m)	36" (900mm)	30" (750mm)	12	7(22)
Greater than or equal to 56' (16.8 m) and less than 65' (19.8 m)	21'-0" (6.4 m)	42" (1060mm)	36" (900mm)	16	8(25)
Greater than or equal to 65' (19.8 m) and up to 75' (22.9 m)	25'-0" (7.6 m)	42" (1060mm)	36" (900mm)	16	8(25)


- NOTES:**
1. These foundation depths are for sites which have cohesive soils (clayey silt, sandy clay, etc.) along the length of the shaft, with an average Unconfined Compressive Strength (Qu) > 1.0 tsf (100 kpa). This strength shall be verified by boring data prior to construction or with testing by the Engineer during foundation drilling. The Bureau of Bridges & structures should be contacted for a revised design if other conditions are encountered.
 2. Combination mast arm assemblies under 55 feet (16.8 m) shall use 36" (900 mm) diameter foundations.
 3. Combination mast arm assemblies under 56 feet (16.8 m) through 75 feet (22.9 m) shall use 42" (1060 mm) diameter foundations
 4. For mast arm assemblies with dual arms refer to state standard 878001..

DEPTH OF MAST ARM FOUNDATIONS, TYPE E

	USER NAME = footemj	DESIGNED -	REVISED -	STATE OF ILLINOIS DEPARTMENT OF TRANSPORTATION	DISTRICT ONE STANDARD TRAFFIC SIGNAL DESIGN DETAILS				F.A. RTE.	SECTION	COUNTY	TOTAL SHEETS	SHEET NO.
		DRAWN -	REVISED -							19-00514-00-WR	KANE	304	158
	PLOT SCALE = 50.00000 ' / in.	CHECKED -	REVISED -		TS-05				CONTRACT NO. 61L28				
	PLOT DATE = 3/4/2019	DATE -	REVISED -		SCALE: NONE	SHEET 5	OF 7 SHEETS	STA. N/A	TO STA. N/A	ILLINOIS FED. AID PROJECT			




 CONCRETE FOUNDATION,
TYPE A 12-INCH DIAMETER



1. THE SIGN PANELS SHALL BE TYPE AP SHEETING.
2. THE ARROW ON SIGNS FOR PUSH-BUTTONS SERVING TWO DIRECTIONS ON THE SAME PHASE SHALL BE BI-DIRECTIONAL.
3. THE SIGN FOR DUAL-CALL PUSH-BUTTONS SHALL HAVE NO ARROW.

SIGN PANEL – TYPE 1 OR TYPE 2

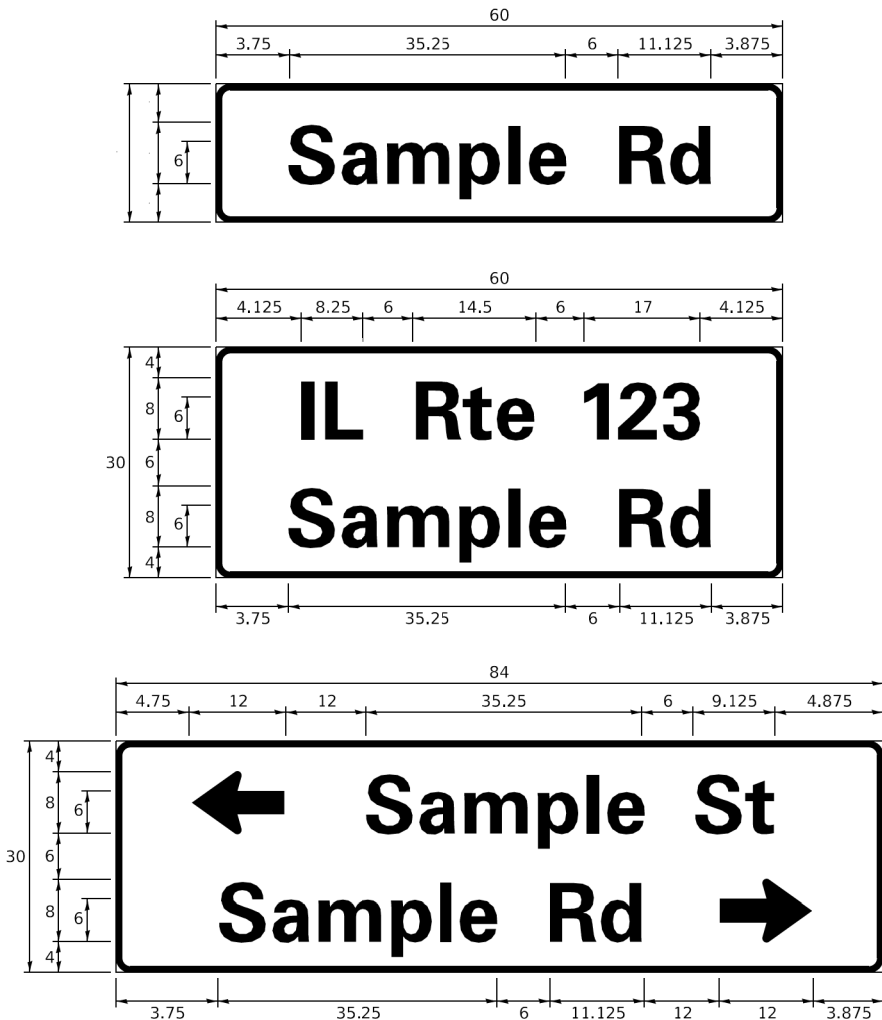

DESIGN SERIES	AREA (SQ FT)	SIGN PANEL TYPE	SHEETING TYPE	QTY. REQUIRED
D OR C	-	1 OR 2	ZZ	-

COMMON STREET NAME ABBREVIATIONS AND WIDTHS

NAME	ABBREVIATION	WIDTH (INCH)	
		SERIES "C"	SERIES "D"
AVENUE	Ave	15.000	18.250
BOULEVARD	Blvd	17.125	20.000
CIRCLE	Cir	11.125	13.000
COURT	Ct	8.250	9.625
DRIVE	Dr	8.625	10.125
HIGHWAY	Hwy	18.375	22.000
ILLINOIS	IL	7.000	8.250
LANE	Ln	9.125	10.750
PARKWAY	Pkwy	23.375	27.375
PLACE	Pl	7.125	7.750
ROAD	Rd	9.625	11.125
ROUTE	Rte	12.625	14.500
STREET	St	8.000	9.125
TERRACE	Ter	12.625	14.625
TRAIL	Tr	7.750	9.125
UNITED STATES	US	10.375	12.250

GENERAL NOTES

- WHERE MAST ARM MOUNTED STREET NAME SIGNS ARE SPECIFIED, THE MAST ARM ASSEMBLY AND POLES SHALL BE DESIGNED TO SUPPORT THE LOADINGS CALLED FOR ON STANDARDS 877001, 877002, 877006, 877011 AND 877012, AS APPLICABLE, PLUS TWO (2) SIGN PANELS 2'-6" x 8'-0" MOUNTED AS SHOWN. THE DESIGN SHALL BE IN ACCORDANCE WITH THE REQUIREMENTS OF THE CURRENT "STANDARD SPECIFICATIONS FOR STRUCTURAL SUPPORTS FOR HIGHWAY SIGNS, LUMINAIRES, AND TRAFFIC SIGNALS" AS PUBLISHED BY THE AMERICAN ASSOCIATION OF STATE HIGHWAY AND TRANSPORTATION OFFICIALS FOR 80 M.P.H. WIND VELOCITY.
- ALL SIGNS SHALL CONSIST OF A WHITE LEGEND AND BORDER (TYPE ZZ SHEETING) ON A GREEN BACKGROUND (TYPE ZZ SHEETING)
- THE SIGN LENGTH SHALL BE IN 6-INCH INCREMENTS, BUT THE OVERALL LENGTH SHALL NOT EXCEED 8'-0". ALL BORDERS IF POSSIBLE, BUT MAY BE REDUCED TO 5" WHEN SPACING IS CRITICAL. A MINIMUM OF 2-1/2" SHALL BE INCLUDED BETWEEN THE WORD AND THE RIGHT AND LEFT EDGES OF THE SIGN.
- A PREFERRED METHOD FOR THE SIGN DESIGN IS TO USE SERIES "D" LETTER ON A ONE-LINE SIGN 18" IN HEIGHT AND A MAXIMUM OF 8'-0" IN WIDTH. IF SERIES "D" DOES NOT FIT ON A 8'-0" SIGN, THEN SERIES "C" SHOULD BE TRIED. IF SERIES "C" DOES NOT FIT ON A 8'-0" SIGN, A 30" HIGH TWO-LINE SIGN CAN BE USED. THE CROSSROAD DESIGNATION AS TO STREET, AVENUE, ETC. SHOULD BE SPELLED OUT ON THE SECOND LINE, IF THE ABBREVIATION CANNOT FIT ON THE FIRST LINE.
- LED ILLUMINATED STREET NAME SIGNS CAN BE USED IN PLACE OF REGULAR SIGN PANELS BUT ANY SPECIAL WORDING AND SYMBOLOGY MUST BE APPROVED BY THE DEPARTMENT. GENERAL DESIGN REQUIREMENT AS LISTED ABOVE (COLOR, FONT, SIZE, ETC.) MUST BE FOLLOWED.
- SIGNFIX ALUMINUM CHANNEL FRAMING SYSTEM SHALL BE USED FOR ALL SIGNS ATTACHED TO SIGNAL POLES AND POSTS.

LOCAL SUPPLIERS:

- J.O. HERBERT COMPANY, INC
MIDLOTHIAN, VA

- WESTERN REMAC, INC.
WOODRIDGE, IL

PARTS LISTING:


SIGN CHANNEL
SIGN SCREWS

BRACKETS


PART #HPN053 (MED. CHANNEL)
1/4" x 14 x 1" H.W.H. #3
SELF TAPPING WITH NEOPRENE WASHER
PART #HPN034 (UNIVERSAL)
CHANNEL CLAMPS WITH STAINLESS STEEL STRAPPING

OTHER BRANDS OF MOUNTING HARDWARE ARE ACCEPTABLE, BASED UPON THE DEPARTMENT'S APPROVAL AND COMPATIBILITY WITH THE CHANNEL/BACKET OF THE ABOVE PRODUCT.

MOUNTING LOCATION

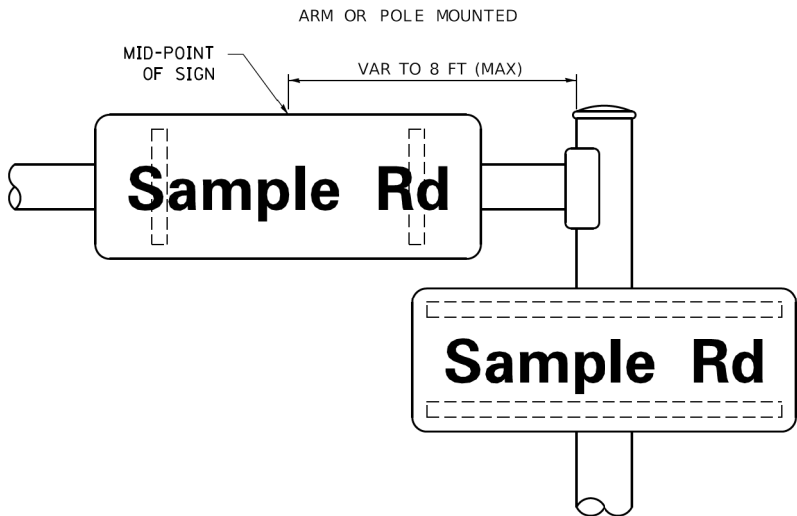

SUPPORTING CHANNELS

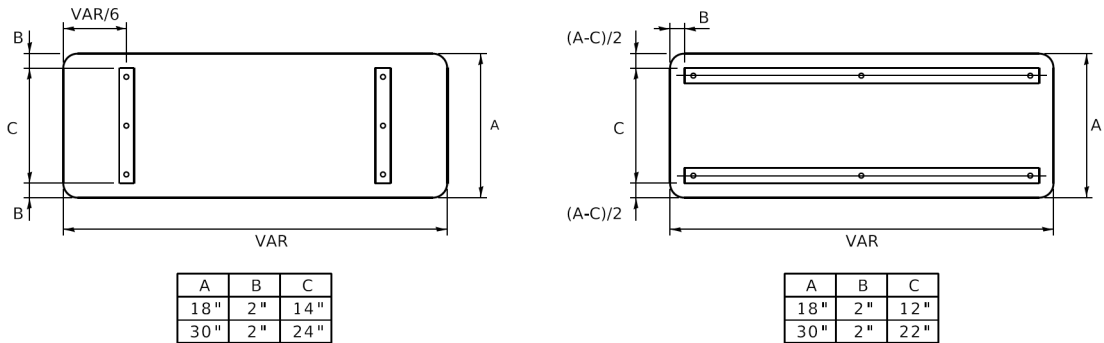

STANDARD ALPHABETS SPACING CHART

(8") UPPER CASE AND (6") LOWER CASE

FHWA SERIES "C"				FHWA SERIES "D"			
CHARACTER	LEFT SPACING (INCH)	WIDTH (INCH)	RIGHT SPACING (INCH)	CHARACTER	LEFT SPACING (INCH)	WIDTH (INCH)	RIGHT SPACING (INCH)
A	0.240	5.122	0.240	A	0.240	6.804	0.240
B	0.880	4.482	0.480	B	0.960	5.446	0.400
C	0.720	4.482	0.720	C	0.800	5.446	0.800
D	0.880	4.482	0.720	D	0.960	5.446	0.800
E	0.880	4.082	0.480	E	0.960	4.962	0.400
F	0.880	4.082	0.240	F	0.960	4.962	0.240
G	0.720	4.482	0.720	G	0.800	5.446	0.800
H	0.880	4.482	0.880	H	0.960	5.446	0.960
I	0.880	1.120	0.880	I	0.960	1.280	0.960
J	0.240	4.082	0.880	J	0.240	5.122	0.960
K	0.880	4.482	0.480	K	0.960	5.604	0.400
L	0.880	4.082	0.240	L	0.960	4.962	0.240
M	0.880	5.284	0.880	M	0.960	6.244	0.960
N	0.880	4.482	0.880	N	0.960	5.446	0.960
O	0.720	4.722	0.720	O	0.800	5.684	0.800
P	0.880	4.482	0.720	P	0.960	5.446	0.240
Q	0.720	4.722	0.720	Q	0.800	5.684	0.800
R	0.880	4.482	0.480	R	0.960	5.446	0.400
S	0.480	4.482	0.480	S	0.400	5.446	0.400
T	0.240	4.082	0.240	T	0.240	4.962	0.240
U	0.880	4.482	0.880	U	0.960	5.446	0.960
V	0.240	4.962	0.240	V	0.240	6.084	0.240
W	0.240	6.084	0.240	W	0.240	7.124	0.240
X	0.240	4.722	0.240	X	0.400	5.446	0.400
Y	0.240	5.122	0.240	Y	0.240	6.884	0.240
Z	0.480	4.482	0.480	Z	0.400	5.446	0.400
a	0.320	3.842	0.640	a	0.400	4.562	0.720
b	0.720	4.082	0.480	b	0.800	4.802	0.480
c	0.480	4.002	0.240	c	0.480	4.722	0.240
d	0.480	4.082	0.720	d	0.480	4.802	0.800
e	0.480	4.082	0.320	e	0.480	4.722	0.320
f	0.320	2.480	0.160	f	0.320	2.882	0.160
g	0.480	4.082	0.720	g	0.480	4.802	0.800
h	0.720	4.082	0.640	h	0.800	4.722	0.720
i	0.720	1.120	0.720	i	0.800	1.280	0.800
j	0.000	2.320	0.720	j	0.000	2.642	0.800
k	0.720	4.322	0.160	k	0.800	5.122	0.160
l	0.720	1.120	0.720	l	0.800	1.280	0.800
m	0.720	6.724	0.640	m	0.800	7.926	0.720
n	0.720	4.082	0.640	n	0.800	4.722	0.720
o	0.480	4.082	0.480	o	0.480	4.882	0.480
p	0.720	4.082	0.480	p	0.800	4.802	0.480
q	0.480	4.082	0.720	q	0.480	4.802	0.800
r	0.720	2.642	0.160	r	0.800	3.042	0.160
s	0.320	3.362	0.240	s	0.320	3.762	0.240
t	0.080	2.882	0.080	t	0.080	3.202	0.080
u	0.640	4.082	0.720	u	0.720	4.722	0.800
v	0.160	4.722	0.160	v	0.160	5.684	0.160
w	0.160	7.524	0.160	w	0.160	9.046	0.160
x	0.000	5.202	0.000	x	0.000	6.244	0.000
y	0.160	4.962	0.160	y	0.160	6.004	0.160
z	0.240	3.362	0.240	z	0.240	4.002	0.240
1	0.720	1.680	0.880	1	0.800	2.000	0.960
2	0.480	4.482	0.480	2	0.800	5.446	0.800
3	0.480	4.482	0.480	3	1.440	5.446	0.800
4	0.240	4.962	0.720	4	0.160	6.004	0.960
5	0.480	4.482	0.480	5	0.800	5.446	0.800
6	0.720	4.482	0.720	6	0.800	5.446	0.800
7	0.240	4.482	0.720	7	0.560	5.446	0.560
8	0.480	4.482	0.480	8	0.800	5.446	0.800
9	0.480	4.482	0.480	9	0.800	5.446	0.800
0	0.720	4.722	0.720	0	0.800	5.684	0.800
-	0.240	2.802	0.240	-	0.240	2.802	0.240

MODEL: Default
FILE NAME: p:\w\0848\BID\NTEC\Illinois.gov\HWIDOT\Documents\DOT Offices\District 1\Projects\Dist5\022321\CADData\CAD\sheetst02.dgn
H:\02\03\24\2019\11\09\17\AM\Iloc\footem


USER NAME = footem]	DESIGNED - LP/IP	REVISED - LP 07/01/2015
	DRAWN - LP	REVISED -
PLOT SCALE = 50.0000 ' / in.	CHECKED - IP	REVISED -
PLOT DATE = 3/4/2019	DATE - 10/01/2014	REVISED -

STATE OF ILLINOIS
DEPARTMENT OF TRANSPORTATION


DISTRICT ONE
MAST ARM MOUNTED STREET NAME SIGNS

SCALE: SHEET OF SHEETS STA. N/A TO STA. N/A

F.A. RTE.	SECTION	COUNTY	TOTAL SHEETS	SHEET NO.
	19-00514-00-WR	KANE	304	161
TS-02		CONTRACT NO. 61L28		
ILLINOIS		FED. AID PROJECT		

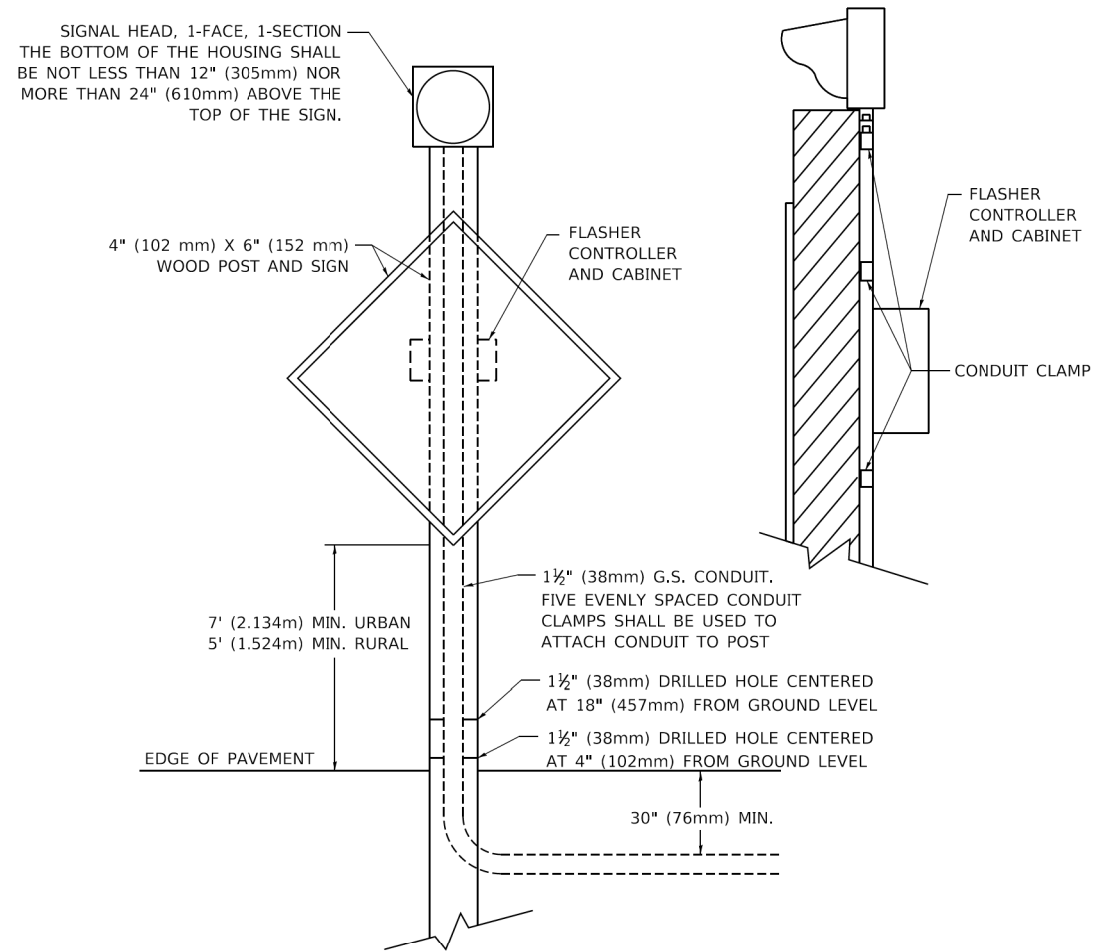

**POST MOUNTED FLASHING BEACON
WITH CONTROLLER AND CABINET**

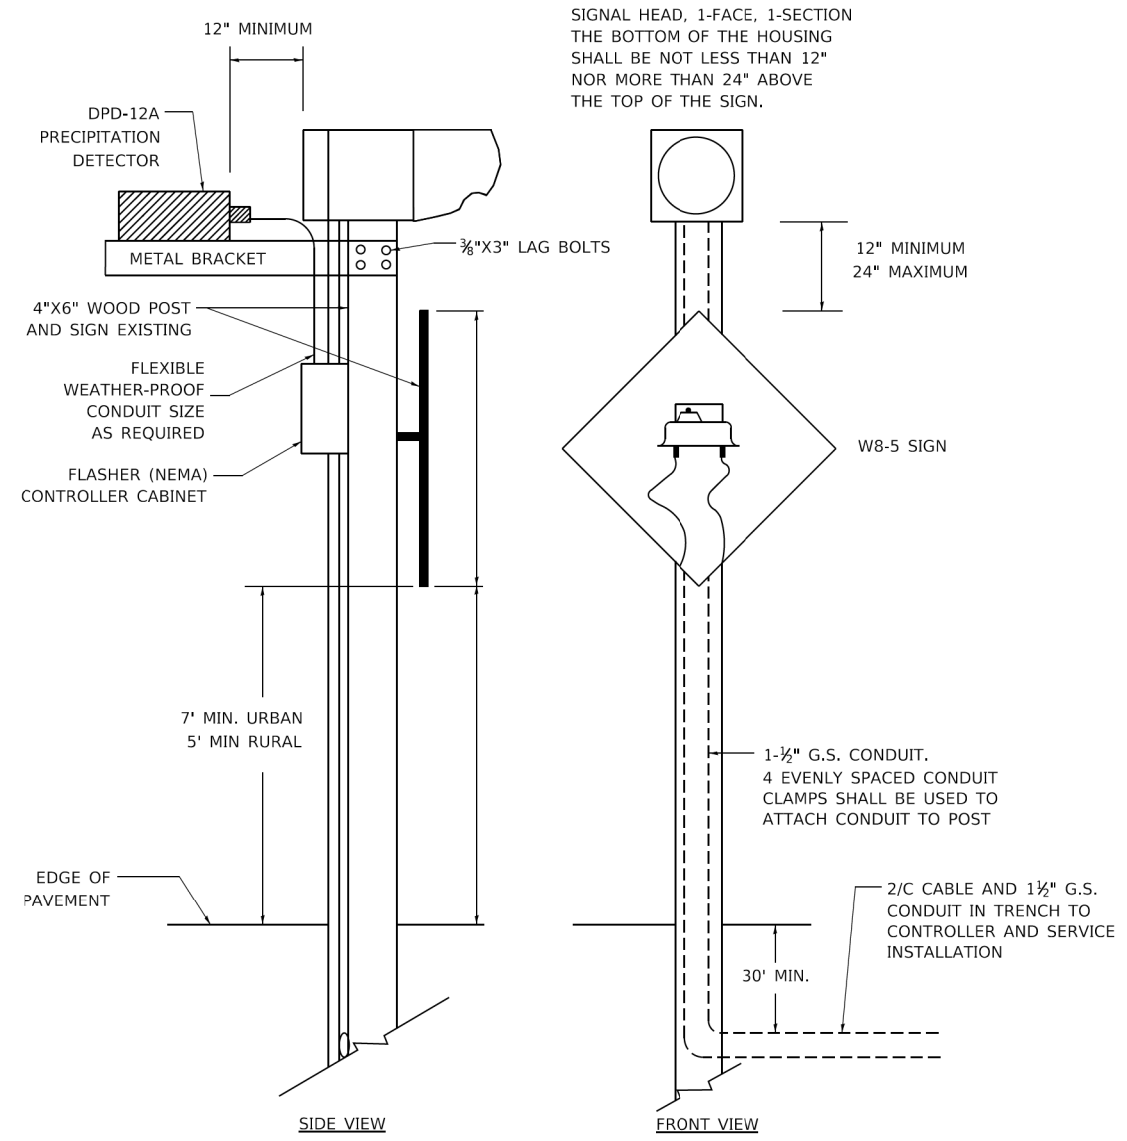

**POST MOUNTED FLASHING BEACON
WITH PRECIPITATION DETECTOR**

MODEL: Default
FILE: \\mte-pw\1084E\BID\NTEC\Illinois.gov\PWIDOT\Documents\DOT Offices\District 1\Projects\Dist5\272341CADData\CAD\Sheet1504.dgn

USER NAME	= footemj	DESIGNED -	TRF	REVISED -	01-01-2007
DRAWN -	LP	REVISED -	07-01-2015		
PLOT SCALE	= 50.0000 ' / in.	CHECKED -		REVISED -	
PLOT DATE	= 3/4/2019	DATE -		REVISED -	

**STATE OF ILLINOIS
DEPARTMENT OF TRANSPORTATION**

**DISTRICT ONE
FLASHING BEACON INSTALLATION DETAILS**

SCALE:	SHEET 1 OF 2 SHEETS	STA. N/A	TO STA. N/A
--------	---------------------	----------	-------------

F.A. RTE.	SECTION	COUNTY	TOTAL SHEETS	SHEET NO.
	19-00514-00-WR	KANE	304	162
TS-04		CONTRACT NO. 61L28		
ILLINOIS		FED. AID PROJECT		

SIGNAL HEAD, 1-FACE, 1-SECTION
THE BOTTOM OF THE HOUSING SHALL
BE NOT LESS THAN 12" (305mm) NOR
MORE THAN 24" (610mm) ABOVE THE
TOP OF THE SIGN.

4" (102 mm) X 6" (152 mm)
WOOD POST AND SIGN

7' (2.134m) MIN. URBAN
5' (1.524m) MIN. RURAL

EDGE OF PAVEMENT

1½" (38mm) G.S. CONDUIT. FIVE
EVENLY SPACED CONDUIT
CLAMPS SHALL BE USED TO
ATTACH CONDUIT TO POST

1½" (38mm) DRILLED HOLE CENTERED
AT 18" (457mm) FROM GROUND LEVEL

1½" (38mm) DRILLED HOLE CENTERED
AT 4" (102mm) FROM GROUND LEVEL

30" (76mm) MIN.

CONDUIT CLAMP

POST MOUNTED FLASHING BEACON

SOLAR FLASHING
BEACON, BATTERY AND
ELECTRONICS

4" (100mm) X 6" (150mm)
WOOD POST

ADVANCE WARNING
SIGN, 48" X 48"

* 12' (3.7 m) MIN. TO
EDGE OF PAVEMENT
6' (1.8 m) MIN. TO
EDGE OF SHOULDER

* 24" (600 mm)
MIN.

ADVANCE STREET NAME PLAQUE
SIGN, W16- 8P, VARI ES" x 12",
DESIGN SERIES "C"
(OPTI ONAL)

1.5" (38 mm) DRILLED HOLE CENTERED
AT 18" (457 mm) AND 4" (102 mm) FROM
GROUND LEVEL

7' (2.1 m) MIN. URBAN
5' (1.5 m) MIN. RURAL

* REFER TO HWY STANDARD 720006
FOR MORE DETAILS

**SOLAR POWERED FLASHING
BEACON**

MODEL: Default
FILE: \\mte-pw\1084E\BID\NTEC\Illinois.gov\PWIDOT\Documents\DOT Offices\District 1\Projects\Dist5\427231\CADData\CAD\sheetst504.dgn

USER NAME = footemj	DESIGNED - TRF	REVISED - 01-01-2007
	DRAWN - LP	REVISED - 07-01-2015
PLOT SCALE = 50.0000 ' / in.	CHECKED -	REVISED -
PLOT DATE = 3/4/2019	DATE -	REVISED -

STATE OF ILLINOIS
DEPARTMENT OF TRANSPORTATION

DISTRICT ONE FLASHING BEACON INSTALLATION DETAILS			
SCALE:	SHEET 2 OF 2 SHEETS	STA. N/A TO STA. N/A	

F.A. RTE.	SECTION	COUNTY	TOTAL SHEETS	SHEET NO.
	19-00514-00-WR	KANE	304	163
TS-04		CONTRACT NO. 61L28		
		ILLINOIS FED. AID PROJECT		

MODEL: Default
FILE NAME: W:\894-088 Randall at Higgins Phase II Engineering\CADD Sheets\016 Traffic Signals\ Existing.dgn



BLA, Inc.





USER NAME = tnestor	DESIGNED - TN	REVISED -
	DRAWN - TN	REVISED -
PLOT SCALE = 48.0000' / in.	CHECKED - GJE	REVISED -
PLOT DATE = 8/21/2025	DATE - 02/15/2025	REVISED -

STATE OF ILLINOIS
DEPARTMENT OF TRANSPORTATION

TEMPORARY TRAFFIC SIGNAL INSTALLATION PLAN AND REMOVE
EXISTING TRAFFIC SIGNAL EQUIPMENT PLAN
RANDALL ROAD AT IL ROUTE 72 (HIGGINS ROAD)

SCALE: 1"=20' SHEET 2 OF 7 SHEETS STA. N/A TO STA. N/A

F.A.P. RTE.	SECTION	COUNTY	TOTAL SHEETS	SHEET NO.
0336	19-00514-00-WR	KANE	304	165
CONTRACT NO. 61L28				
ILLINOIS FED. AID PROJECT				

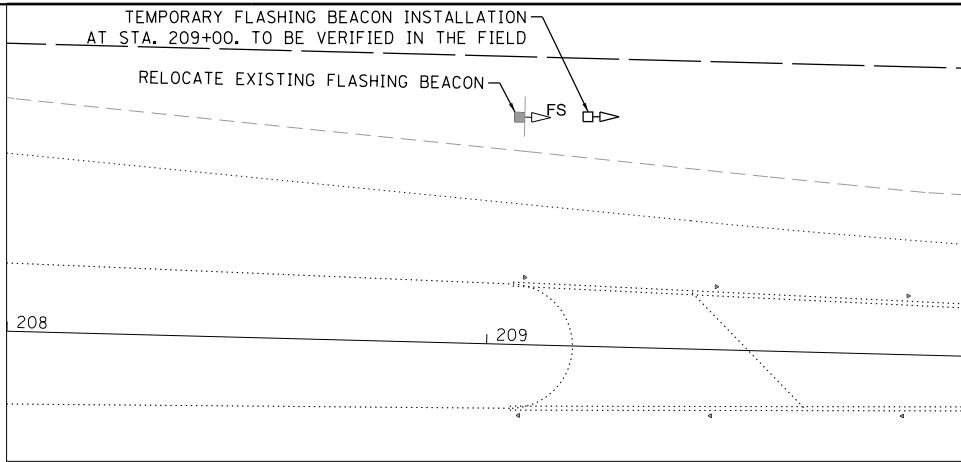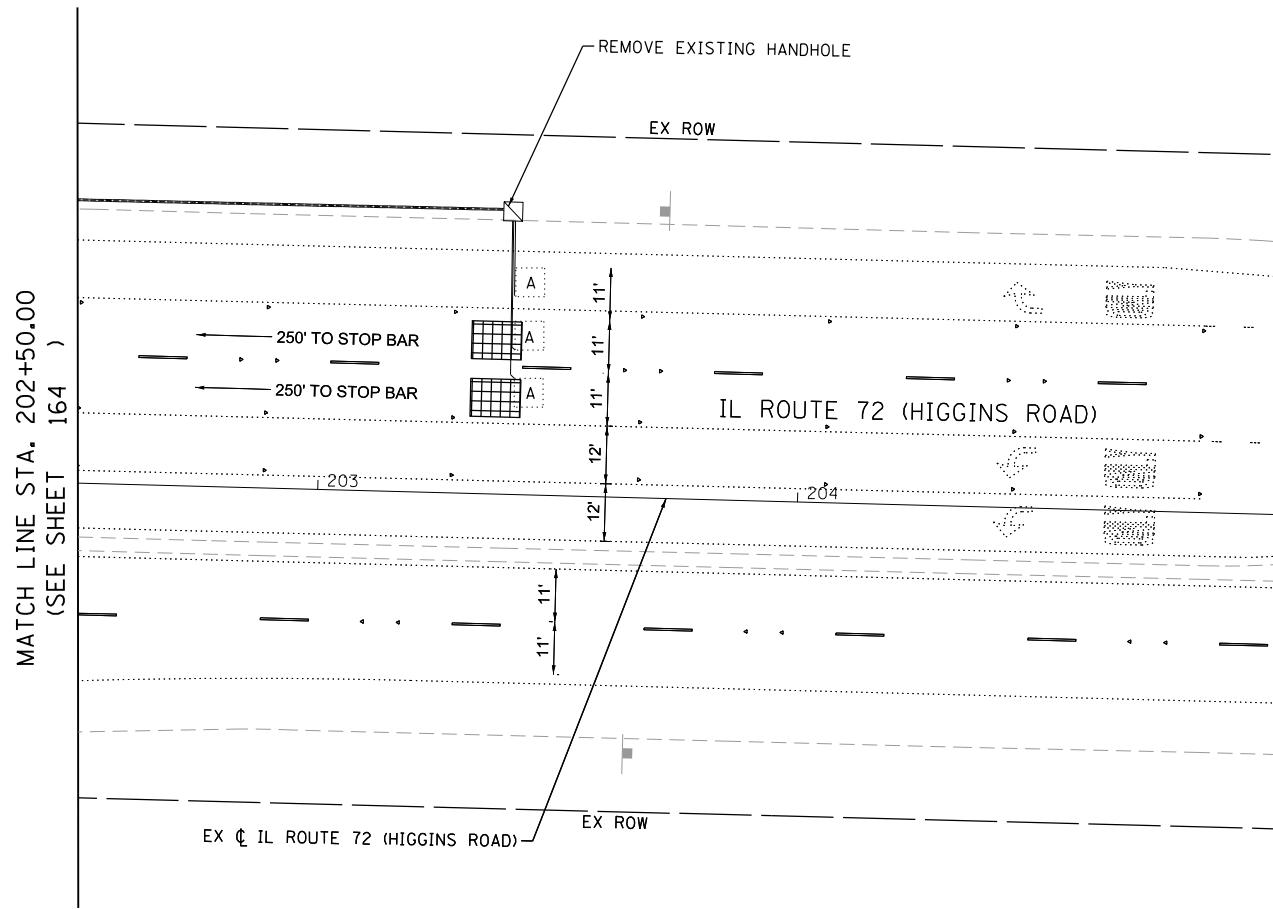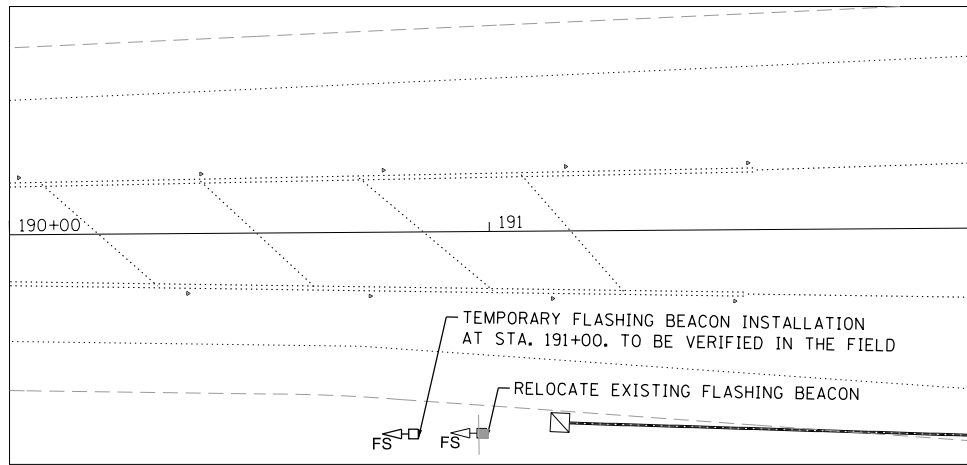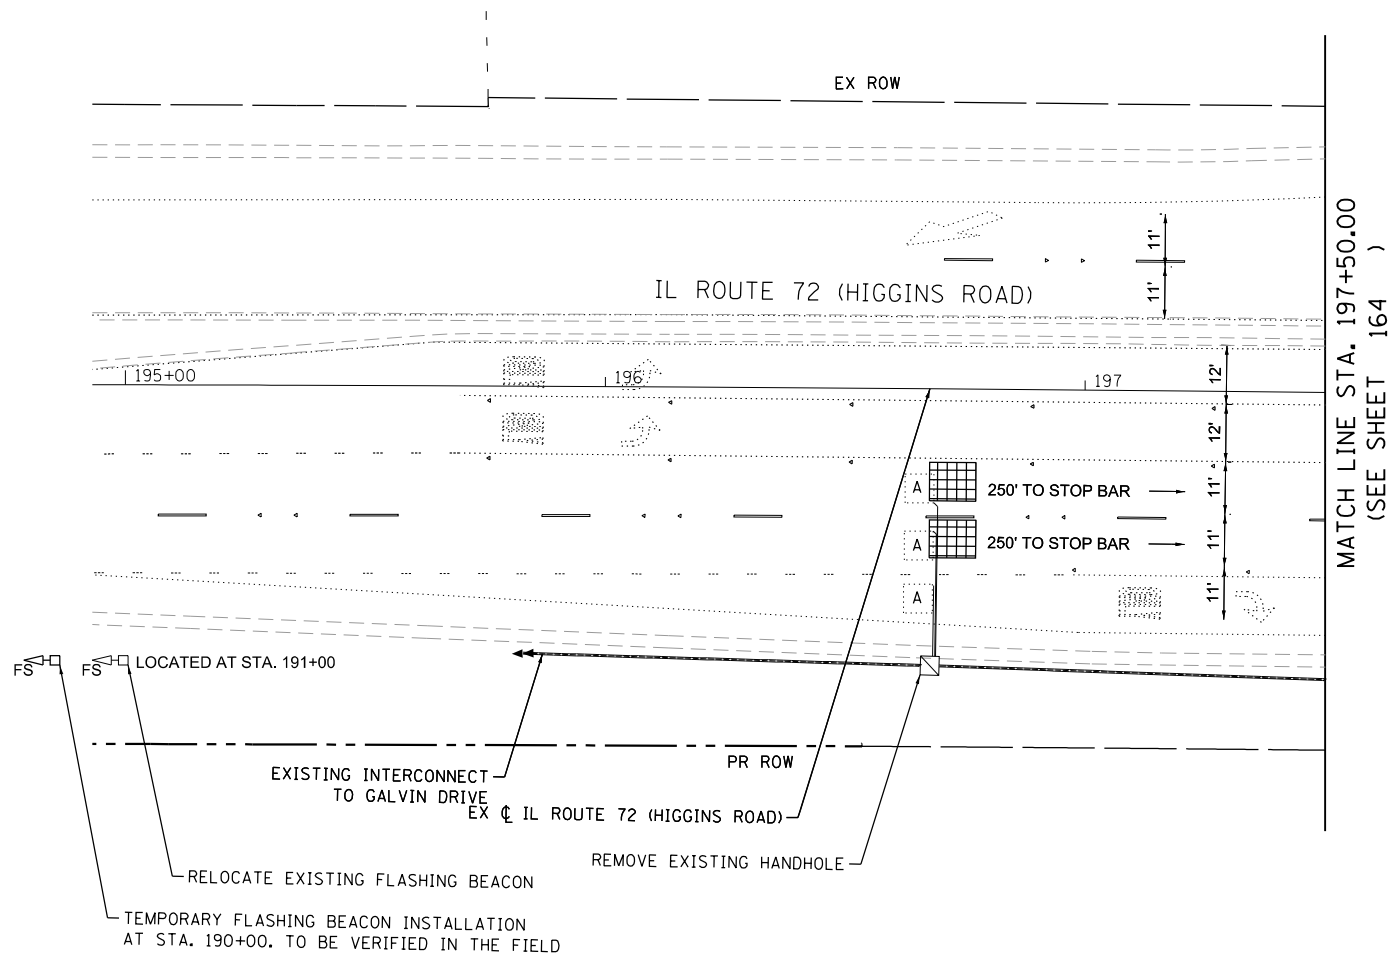

0 20 40 60
SCALE IN FEET

TS 812
FL 762
FL 763
KDOT SYSTEM

MODEL: Default
FILE NAME: V:\894-088 Randall at Higgins Phase II Engineering\CADD Sheets\016 Traffic Signals\19-00514-00-WR_SHT_TEMP Traffic Signals_Existing.dgn



BLA, Inc.

USER NAME = tnestor	DESIGNED - TN	REVISED -
	DRAWN - TN	REVISED -
PLOT SCALE = 48.0000' / in.	CHECKED - GJE	REVISED -
PLOT DATE = 8/21/2025	DATE - 02/15/2025	REVISED -

STATE OF ILLINOIS
DEPARTMENT OF TRANSPORTATION

TEMPORARY TRAFFIC SIGNAL INSTALLATION PLAN AND REMOVE
EXISTING TRAFFIC SIGNAL EQUIPMENT PLAN
RANDALL ROAD AT IL ROUTE 72 (HIGGINS ROAD)

SCALE: 1"=20' SHEET 3 OF 7 SHEETS STA. N/A TO STA. N/A

F.A.P. RTE.	SECTION	COUNTY	TOTAL SHEETS	SHEET NO.
0336	19-00514-00-WR	KANE	304	166
CONTRACT NO. 61L28				
ILLINOIS FED. AID PROJECT				

REMOVE EXISTING FLASHING BEACON
INSTALLATION COMPLETE



LOCATED AT STA. 93+60

EXISTING INTERCONNECT TO
RECREATION DRIVE

PR ROW

REMOVE EXISTING HANDHOLE

A A A



250' TO STOP BAR

250' TO STOP BAR

11' 11'

11' 11'

11' 11'

12' 12'

11' 11'

11' 11'

MATCH LINE STA. 98+20.00
(SEE SHEET 164)

RANDALL ROAD

11' 11'

11' 11'

(SEE SHEET 164)
MATCH LINE STA. 101+70.00

11' 11'

11' 11'

12' 12' 11' 11' 11'

12' 12' 11' 11' 11'

RANDALL ROAD

EX C RANDALL ROAD

250' TO STOP BAR

250' TO STOP BAR

 
REMOVE EXISTING HANDHOLE

EXISTING INTERCONNECT TO
NORTHWEST PKWY / JOY LANE



LOCATED AT STA. 106+35

REMOVE EXISTING FLASHING BEACON
INSTALLATION COMPLETE




TS 812
FL 762
FL 763
KDOT SYSTEM

NOTE: THE SIDEWALK AND MULTI-USE PATH SHALL REMAIN CLOSED AND SIGNED FOR THE CLOSURE UNTIL THE PROPOSED SIGNALS ARE OPERATIONAL



 4 REQUIRED



S 812
FL 762
FL 763
SYSTEM

USER NAME = tnestor	DESIGNED = TN	REVISED =
	DRAWN = TN	REVISED =
PLOT SCALE = 40.0000' / in.	CHECKED = GJE	REVISED =
PLOT DATE = 8/21/2025	DATE = 02/15/2025	REVISED =

**STATE OF ILLINOIS
DEPARTMENT OF TRANSPORTATION**

STAGE 1 TEMPORARY TRAFFIC SIGNAL INSTALLATION PLAN RANDALL ROAD AT IL ROUTE 72 (HIGGINS ROAD)

SCALE: 1"=20'	SHEET 1 OF 7 SHEETS	STA. N/A TO STA. N/A
---------------	---------------------	----------------------

F.A.P. RTE.	SECTION	COUNTY	TOTAL SHEETS	SHEET NO.
0336	19-00514-00-WR	KANE	304	167
		CONTRACT NO. 61L28		
ILLINOIS		FED. AID PROJECT		



BLA, Inc.

MODEL: D:\bls\19-00514-00-WR_Sht_1_TEMP_Traffic_Signals_001.dgn
FILE NAME: 19-00514-00-WR_Sht_1_TEMP_Traffic_Signals_001.dgn



BLA, Inc.

USER NAME : tnestor	DESIGNED - TN	REVISED -
	DRAWN - TN	REVISED -
PLOT SCALE : 40.0000' / in.	CHECKED - GJE	REVISED -
PLOT DATE : 8/21/2025	DATE - 02/15/2025	REVISED -


STATE OF ILLINOIS
DEPARTMENT OF TRANSPORTATION

STAGE 1 TEMPORARY TRAFFIC SIGNAL INSTALLATION PLAN
RANDALL ROAD AT IL ROUTE 72 (HIGGINS ROAD)

SCALE: 1"=20' SHEET 2 OF 7 SHEETS STA. N/A TO STA. N/A




F.A.P. RTE.	SECTION	COUNTY	TOTAL SHEETS	SHEET NO.
0336	19-00514-00-WR	KANE	304	168
CONTRACT NO. 61L28				
ILLINOIS FED. AID PROJECT				



TS 812
FL 762
FL 763
KDOT SYSTEM

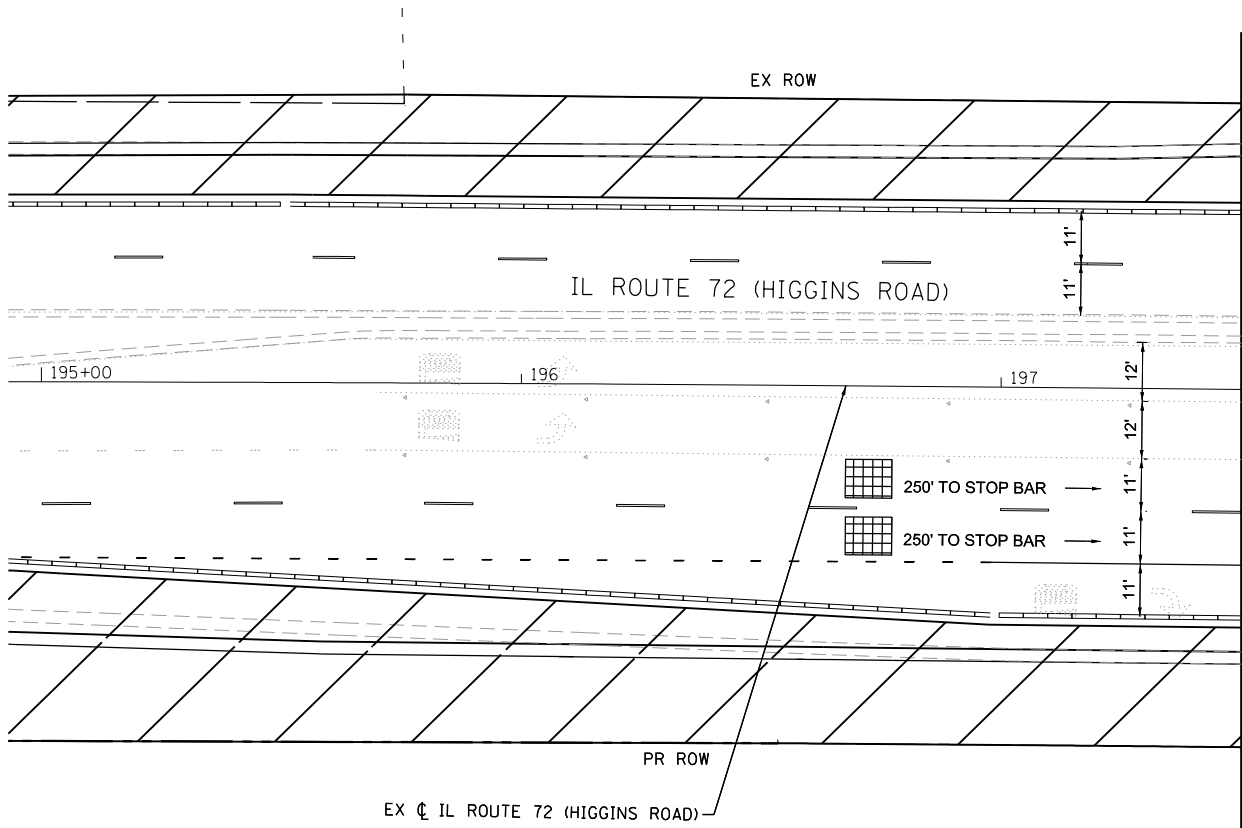

MATCH LINE STA. 197+50.00
(SEE SHEET 167)

MATCH LINE STA. 202+50.00
(SEE SHEET 167)

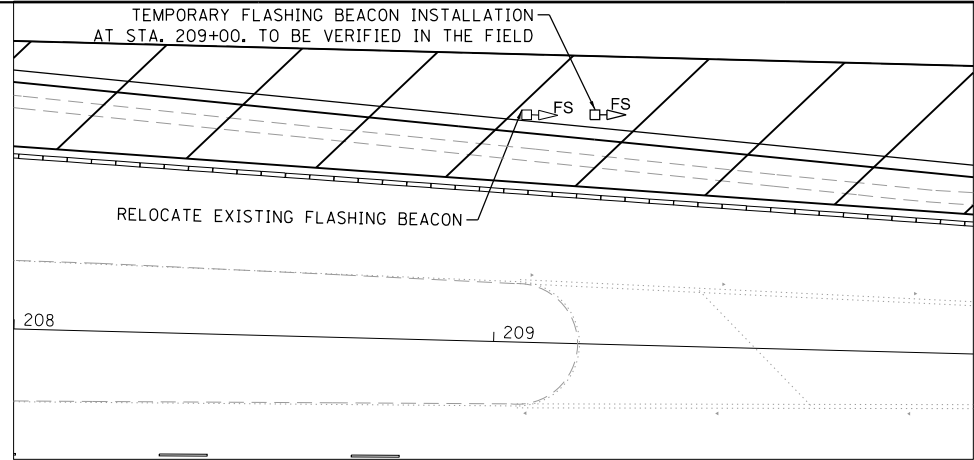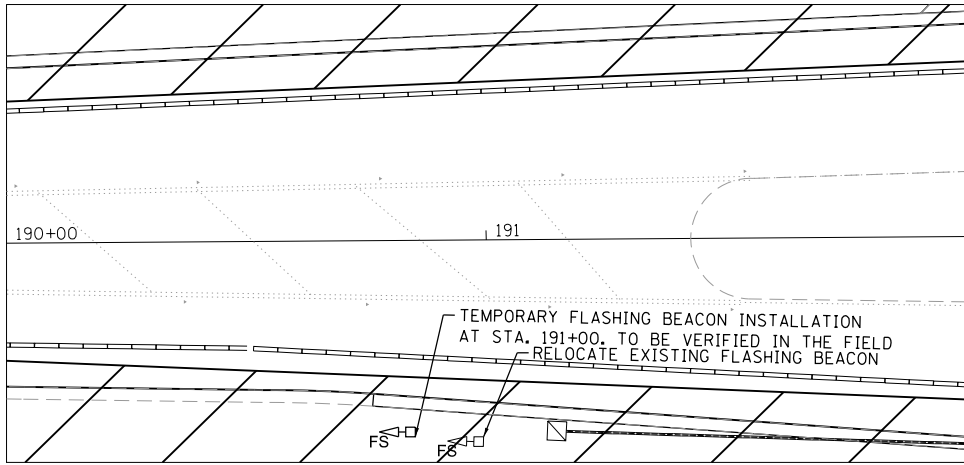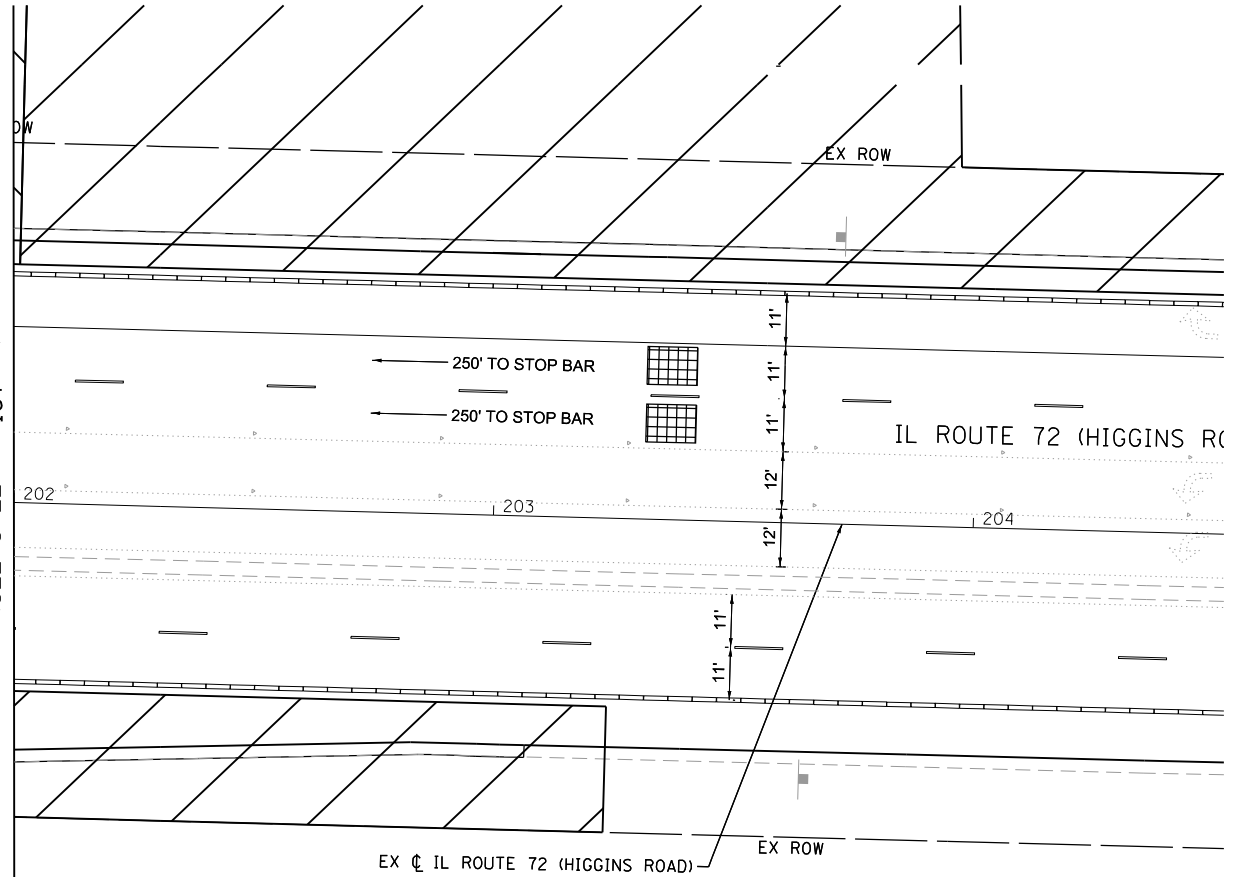

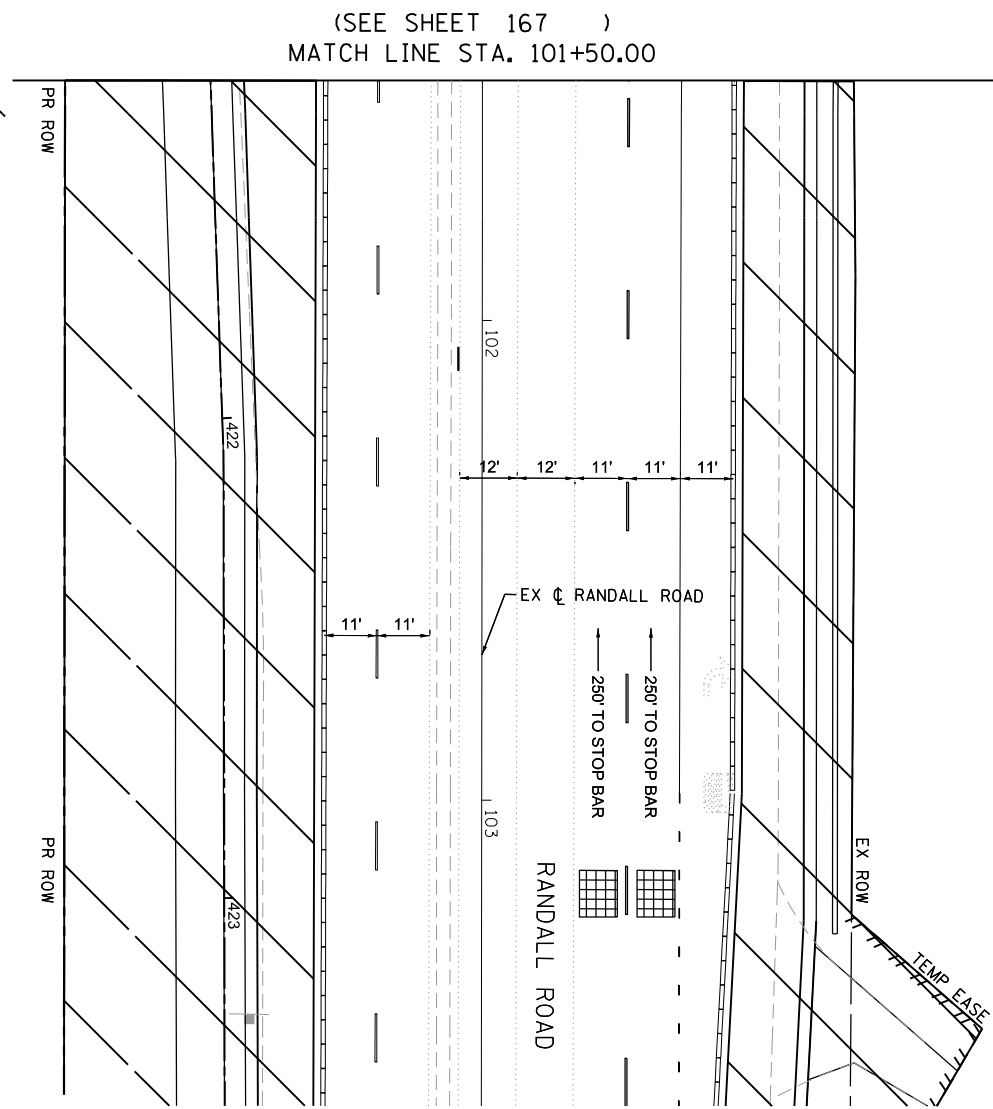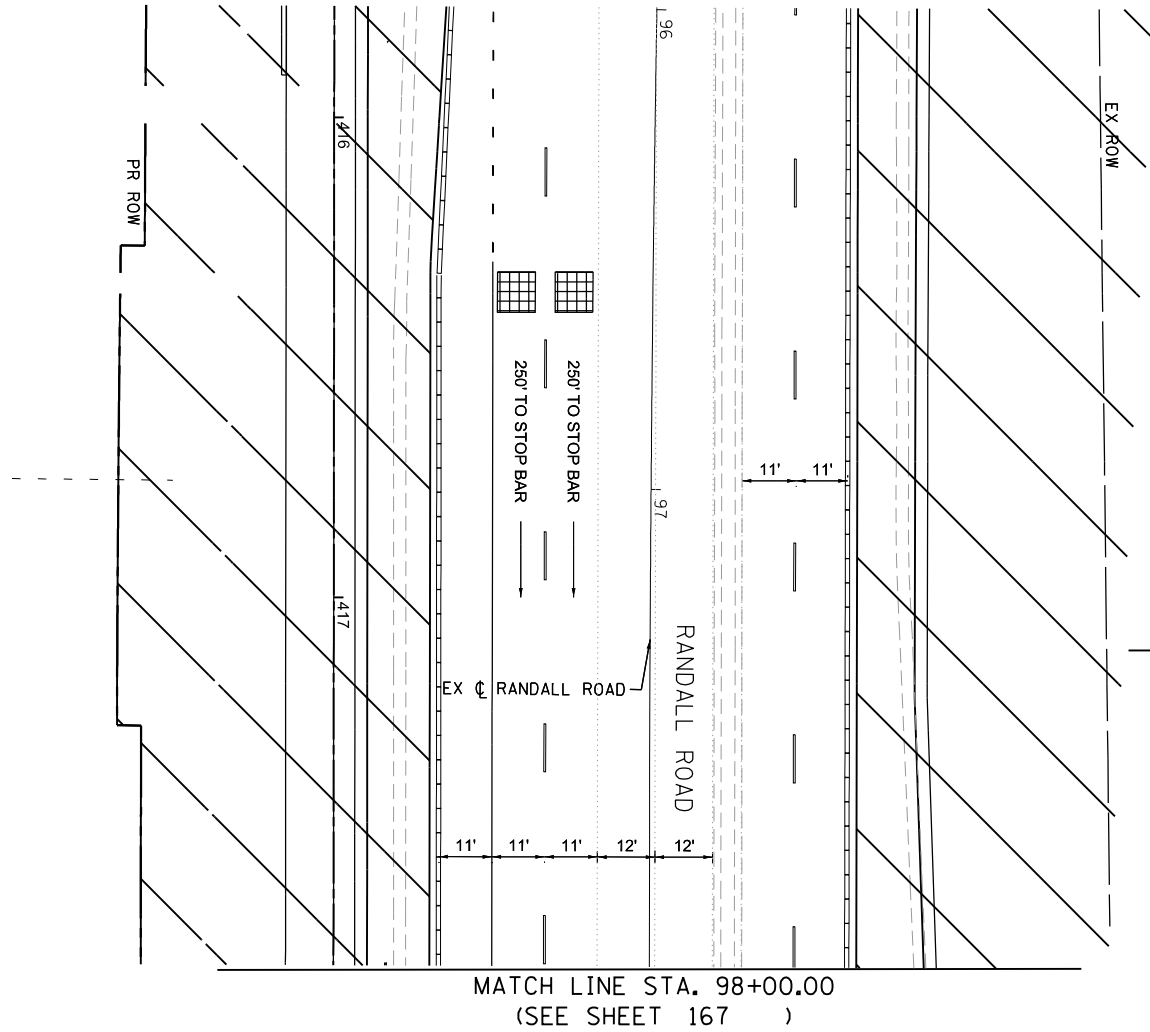

TS 812
FL 762
FL 763
KDOT SYSTEM

MODEL: D:\bls\19-00514-00-WR_SHT_1_TEMP_Traffic_Signals_001.dgn
FILE NAME: 19-00514-00-WR_SHT_1_TEMP_Traffic_Signals_001.dgn



BLA, Inc.

USER NAME : tnestor	DESIGNED - TN	REVISED -
	DRAWN - TN	REVISED -
PLOT SCALE = 40.0000' / in.	CHECKED - GJE	REVISED -
PLOT DATE = 8/21/2025	DATE - 02/15/2025	REVISED -

STATE OF ILLINOIS
DEPARTMENT OF TRANSPORTATION

STAGE 1 TEMPORARY TRAFFIC SIGNAL INSTALLATION PLAN
RANDALL ROAD AT IL ROUTE 72 (HIGGINS ROAD)

SCALE: 1"=20' SHEET 3 OF 7 SHEETS STA. N/A TO STA. N/A

F.A.P. RTE.	SECTION	COUNTY	TOTAL SHEETS	SHEET NO.
0336	19-00514-00-WR	KANE	304	169
CONTRACT NO. 61L28				
ILLINOIS FED. AID PROJECT				

MODEL: D:\bls\19-00514-00-WR_Sht_2_Traffic_Signals.dgn
FILE NAME: 19-00514-00-WR_Sht_2_Traffic_Signals.dgn



BLA, Inc.


USER NAME : tnestor	DESIGNED - TN	REVISED -
	DRAWN - TN	REVISED -
PLOT SCALE : 40.0000' / in.	CHECKED - GJE	REVISED -
PLOT DATE : 8/21/2025	DATE - 02/15/2025	REVISED -

STATE OF ILLINOIS
DEPARTMENT OF TRANSPORTATION



STAGE 2 TEMPORARY TRAFFIC SIGNAL INSTALLATION PLAN
RANDALL ROAD AT IL ROUTE 72 (HIGGINS ROAD)

SCALE: 1"=20' SHEET 4 OF 7 SHEETS STA. N/A TO STA. N/A

F.A.P. RTE.	SECTION	COUNTY	TOTAL SHEETS	SHEET NO.
0336	19-00514-00-WR	KANE	304	170
CONTRACT NO. 61L28				
ILLINOIS FED. AID PROJECT				

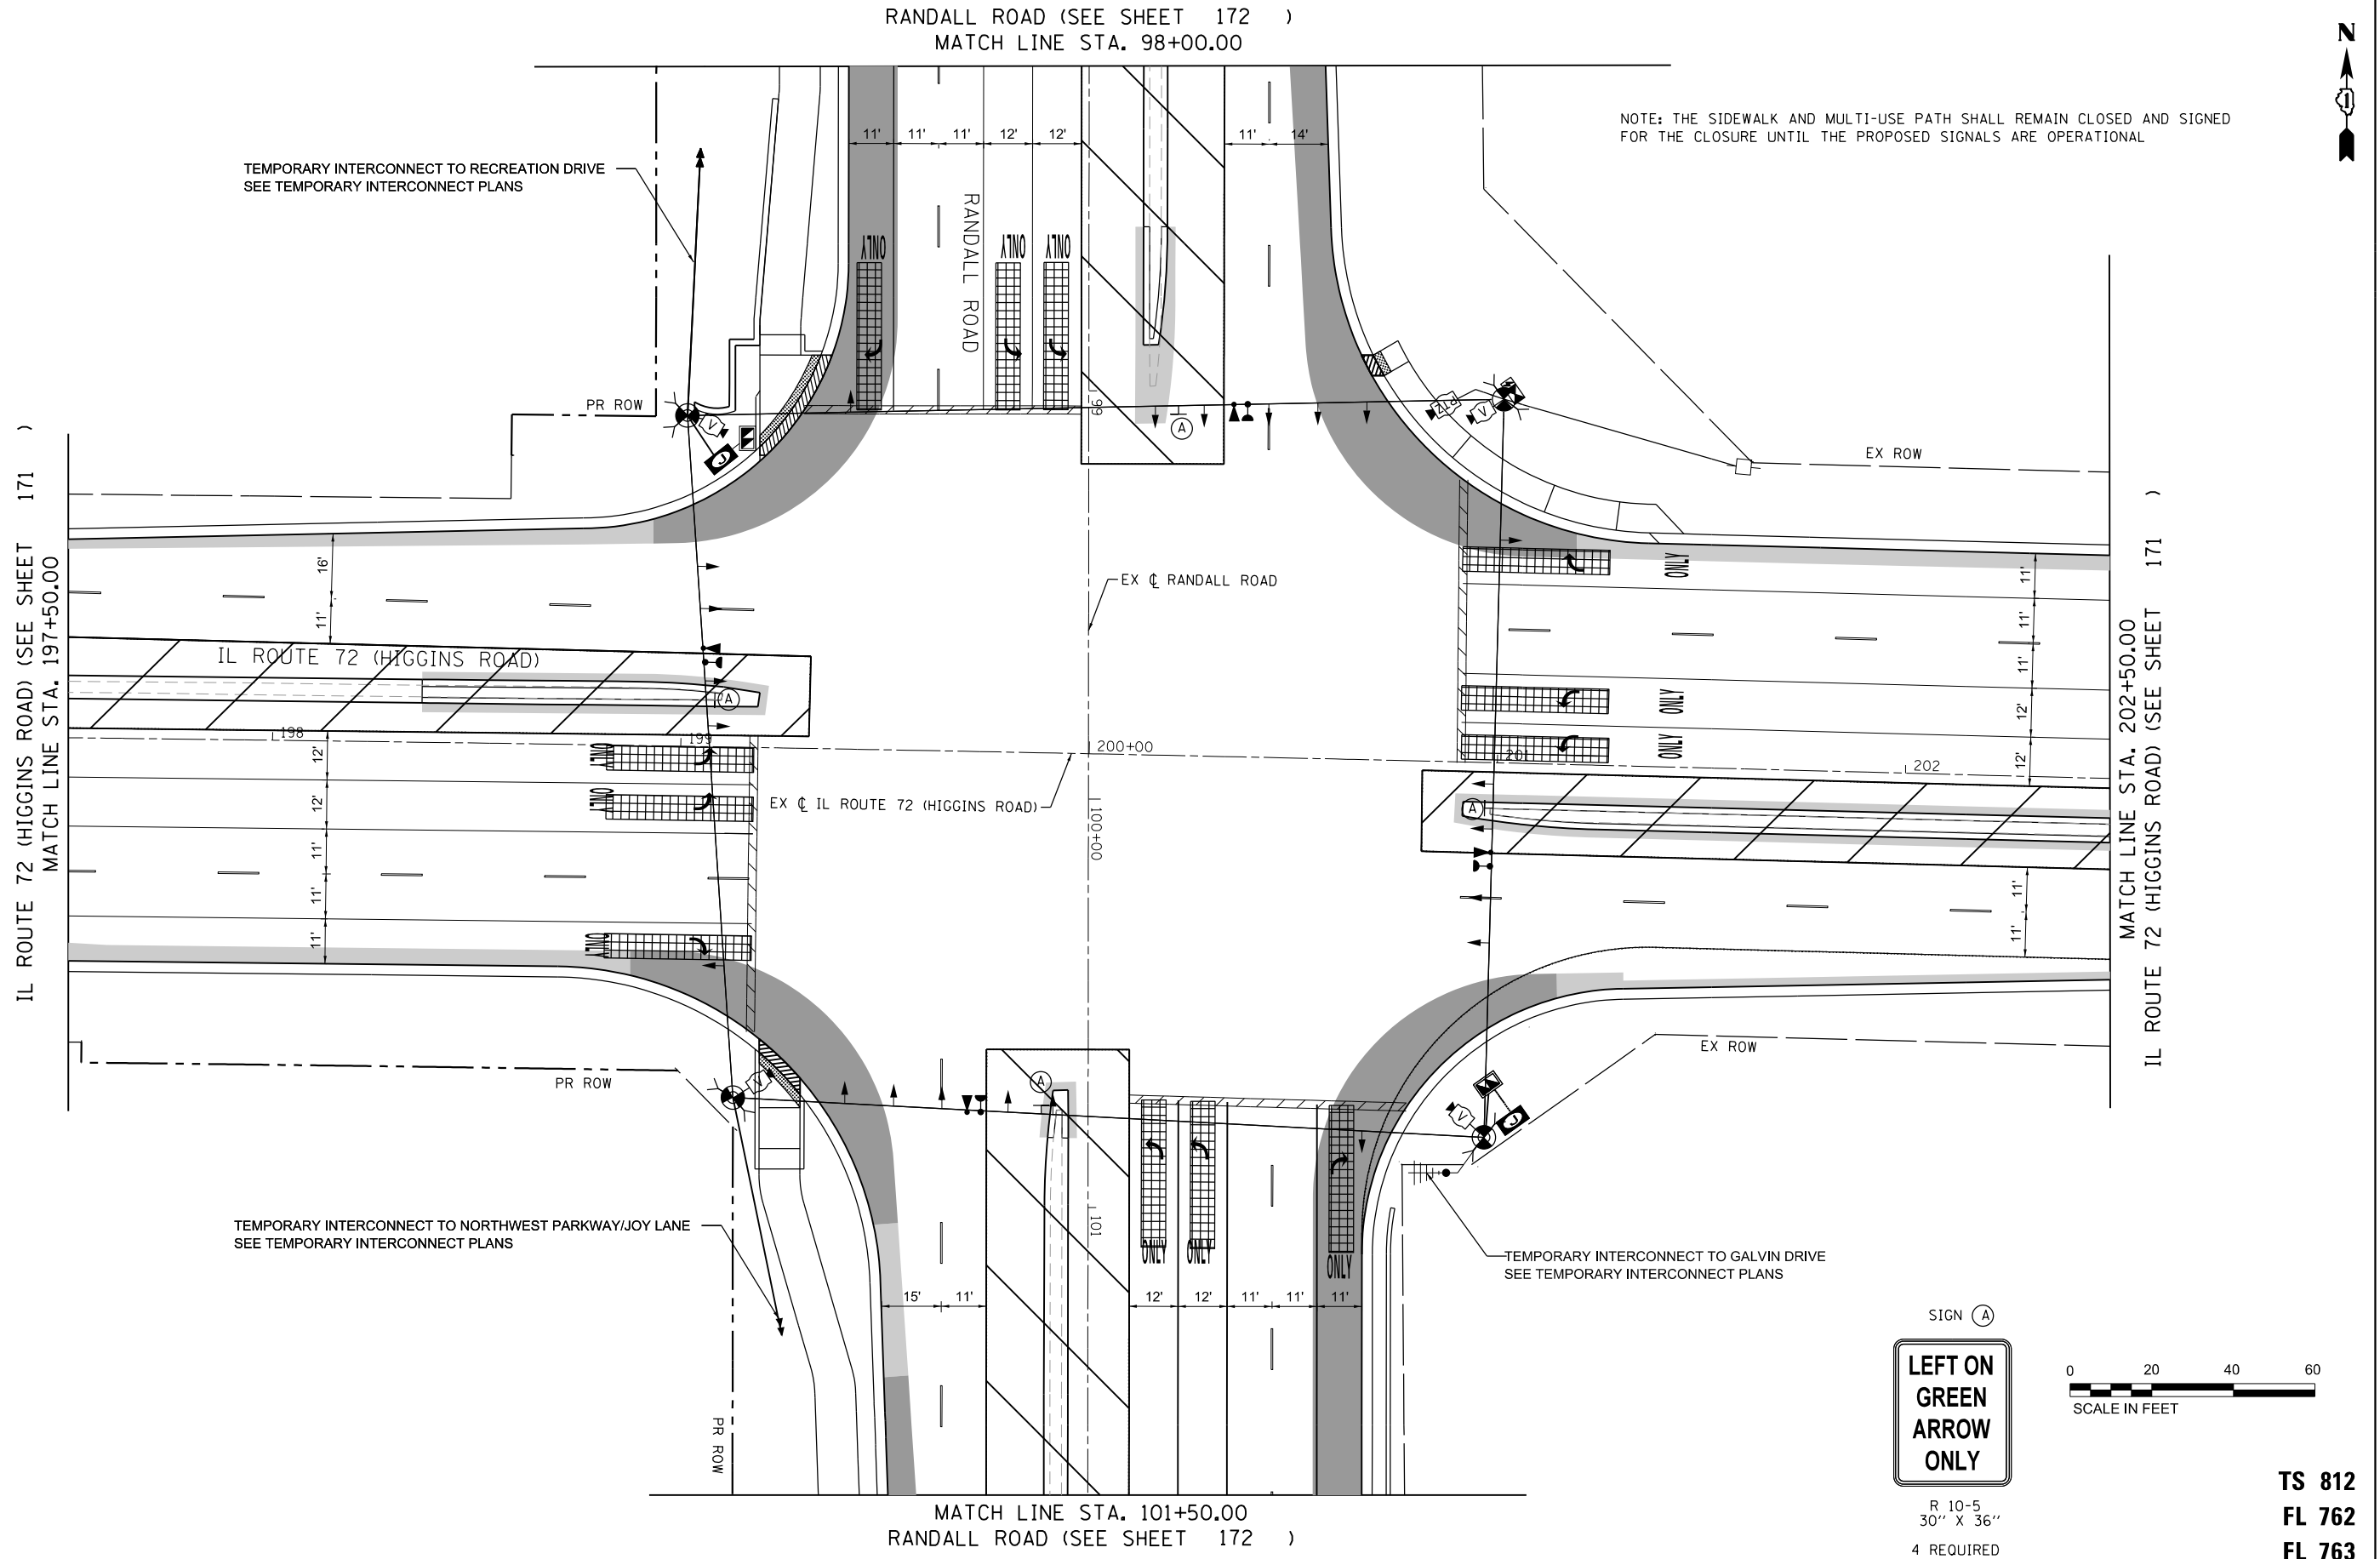

TS 812
FL 762
FL 763
KDOT SYSTEM

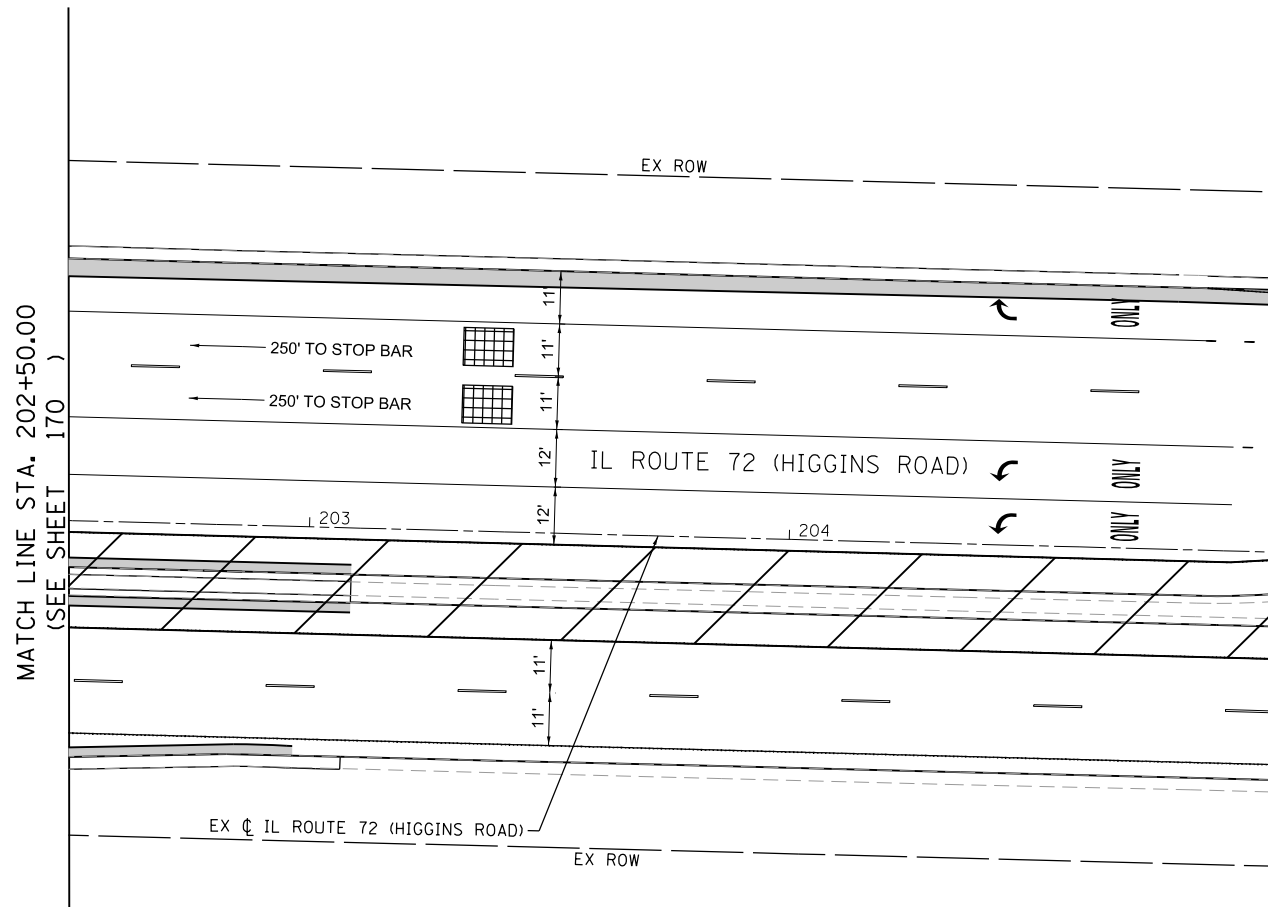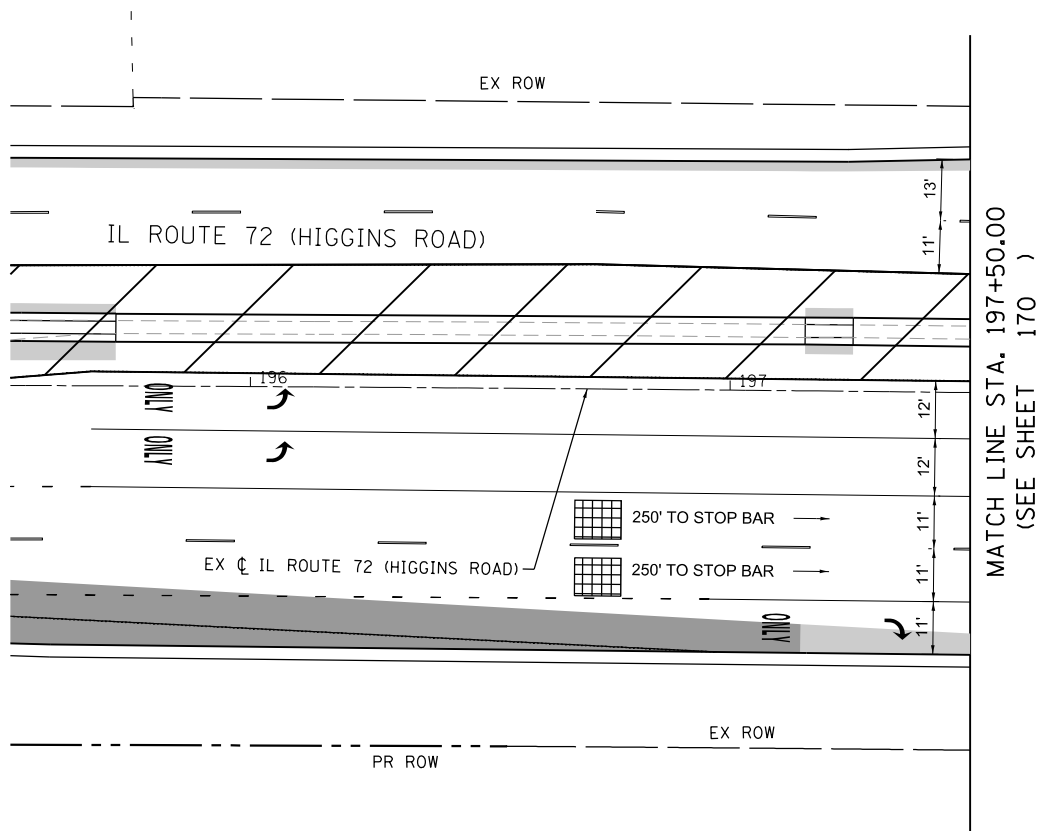

TS 812
FL 762
FL 763
KDOT SYSTEM

MODEL: D:\p1\19-00514-WR-002.dgn
FILE NAME: 19-00514-WR-002.dgn
PROJECT: Phase II Engineering (CADD) Sheets 016 Traffic Signals 19-00514-WR-002.dgn





USER NAME : tnestor	DESIGNED - TN	REVISED -
	DRAWN - TN	REVISED -
PLOT SCALE : 40.0000' / in.	CHECKED - GJE	REVISED -
PLOT DATE : 8/21/2025	DATE - 02/15/2025	REVISED -

STATE OF ILLINOIS
DEPARTMENT OF TRANSPORTATION

STAGE 2 TEMPORARY TRAFFIC SIGNAL INSTALLATION PLAN
RANDALL ROAD AT IL ROUTE 72 (HIGGINS ROAD)

SCALE: 1"=20' SHEET 5 OF 7 SHEETS STA. N/A TO STA. N/A

F.A.P. RTE.	SECTION	COUNTY	TOTAL SHEETS	SHEET NO.
0336	19-00514-00-WR	KANE	304	171
CONTRACT NO. 61L28				
ILLINOIS FED. AID PROJECT				

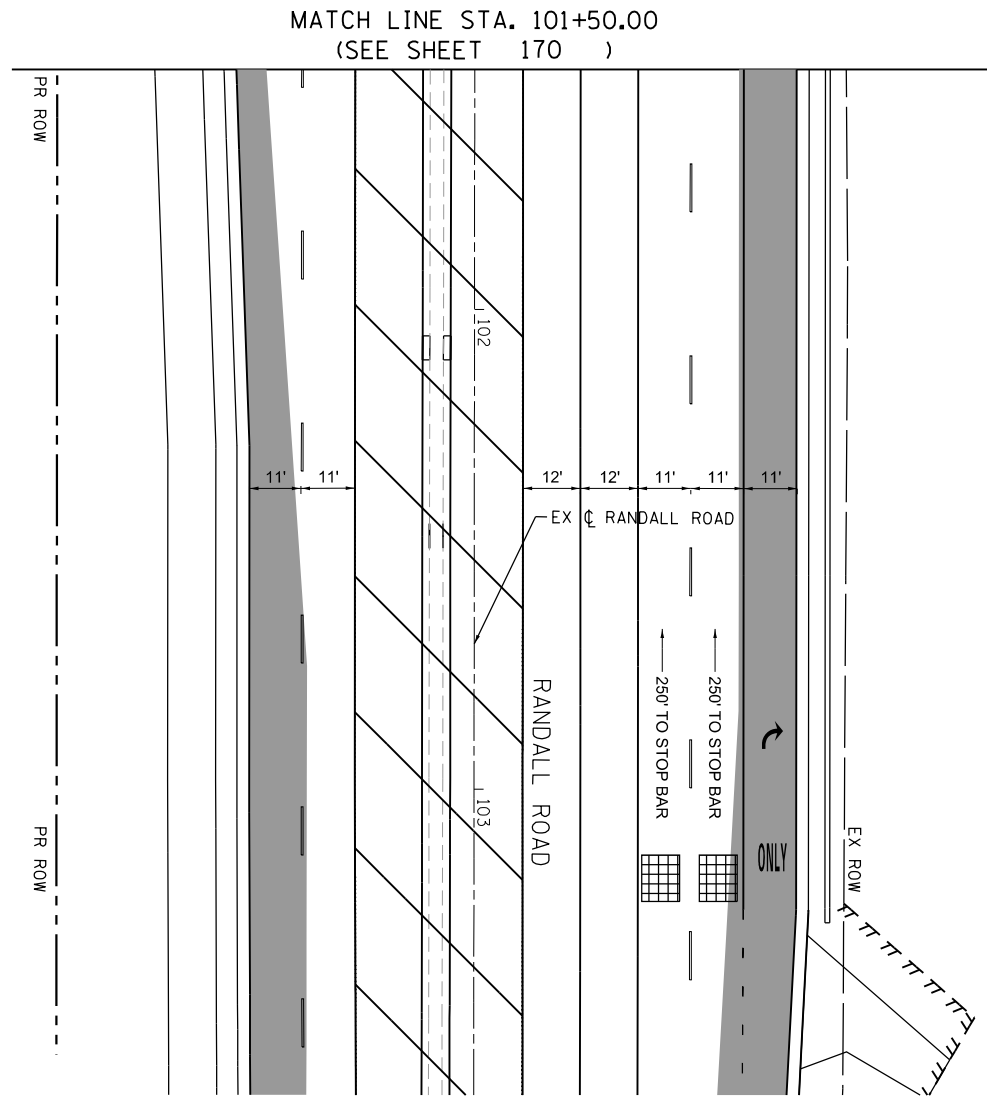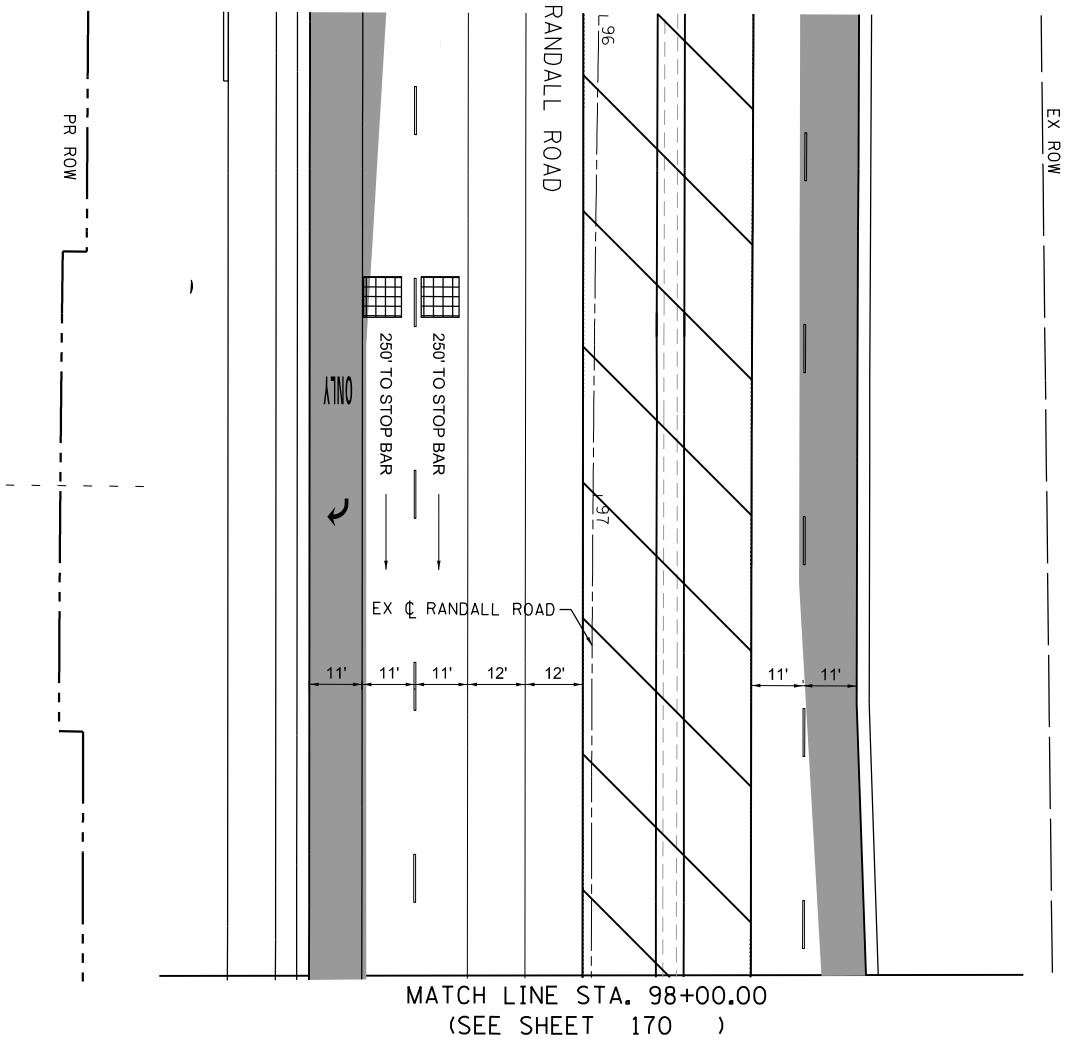

TS 812
FL 762
FL 763
KDOT SYSTEM

MODEL: D:\p1\19-00514-00-WR_SHT_1_TEMP_Traffic Signals_002.dgn
FILE NAME: 19-00514-00-WR_SHT_1_TEMP_Traffic Signals_002.dgn



BLA, Inc.


USER NAME : tnestor	DESIGNED - TN	REVISED -
	DRAWN - TN	REVISED -
PLOT SCALE : 40.0000' / in.	CHECKED - GJE	REVISED -
PLOT DATE : 8/21/2025	DATE - 02/15/2025	REVISED -

STATE OF ILLINOIS
DEPARTMENT OF TRANSPORTATION

STAGE 2 TEMPORARY TRAFFIC SIGNAL INSTALLATION PLAN
RANDALL ROAD AT IL ROUTE 72 (HIGGINS ROAD)

SCALE: 1"=20' SHEET 6 OF 7 SHEETS STA. N/A TO STA. N/A

F.A.P. RTE.	SECTION	COUNTY	TOTAL SHEETS	SHEET NO.
0336	19-00514-00-WR	KANE	304	172
CONTRACT NO. 61L28				
ILLINOIS FED. AID PROJECT				

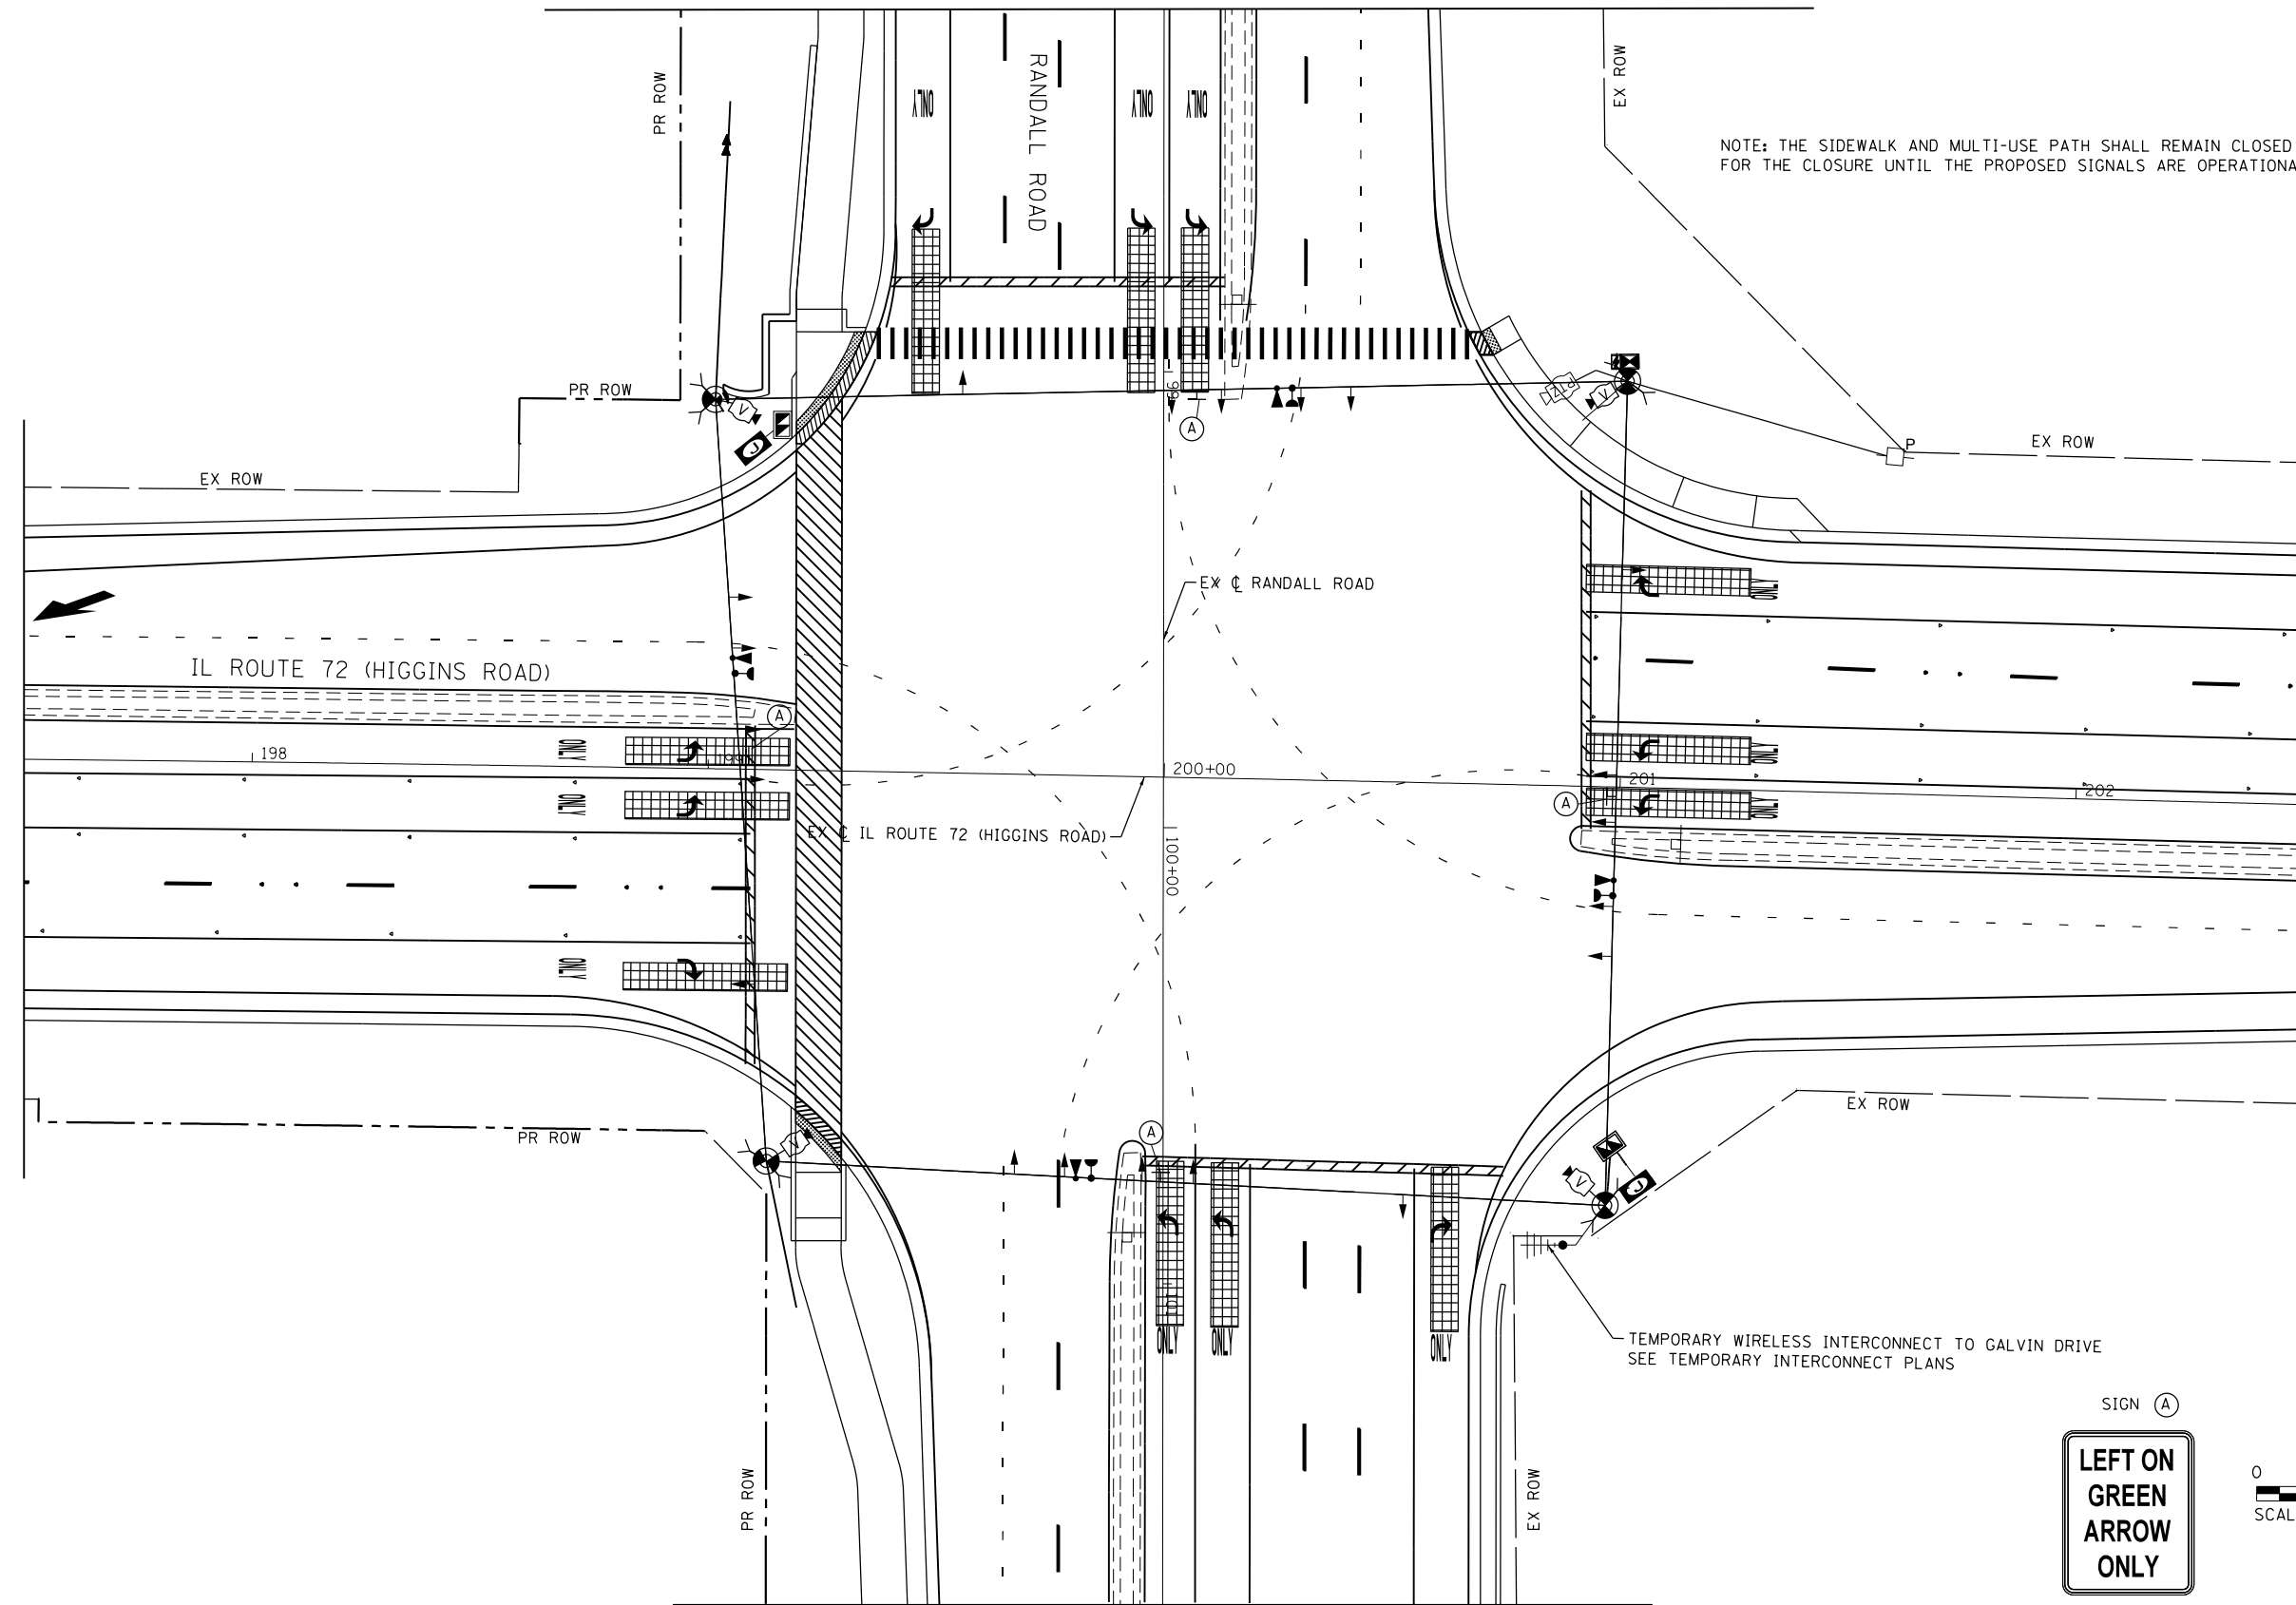

SIGN (A)

**LEFT ON
GREEN
ARROW
ONLY**

R 10-5
30" X 36"

4 REQUIRED



TS 812
FL 762
FL 763
KDOT SYSTEM

MODEL: Default
FILE NAME: V:\894-088 Randall at Higgins Phase II Engineering\CADD Sheets\016 Traffic Signals\19-00514-00-WR_SHT_TEMP_Traffic_Signals_Final.dgn

**BLA, Inc.**

USER NAME = tnestor	DESIGNED - TN	REVISED -
	DRAWN - TN	REVISED -
PLOT SCALE = 48.0000' / in.	CHECKED - GJE	REVISED -
PLOT DATE = 8/21/2025	DATE - 02/15/2025	REVISED -


STATE OF ILLINOIS
DEPARTMENT OF TRANSPORTATION

FINAL GEOMETRY TEMPORARY TRAFFIC SIGNAL PLAN
EXISTING TRAFFIC SIGNAL EQUIPMENT PLAN
RANDALL ROAD AT IL ROUTE 72 (HIGGINS ROAD)

SCALE: 1"=20' SHEET 1 OF 7 SHEETS STA. N/A TO STA. N/A

F.A.P. RTE.	SECTION	COUNTY	TOTAL SHEETS	SHEET NO.
0336	19-00514-00-WR	KANE	304	173
CONTRACT NO. 61L28				
ILLINOIS FED. AID PROJECT				


TEMPORARY CONTROLLER SEQUENCE

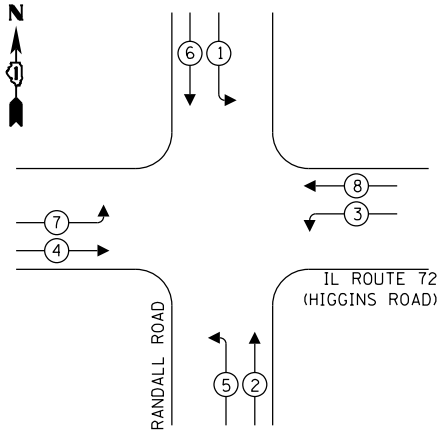

LEGEND:

- ← (⊛) → PROTECTED PHASE
- ← - (⊛) - → PROTECTED/PERMITTED PHASE
- ← (⊛) → PEDESTRIAN PHASE
- ← (⊛) OL → OVERLAP

TEMPORARY EMERGENCY VEHICLE PREEMPTION SEQUENCE

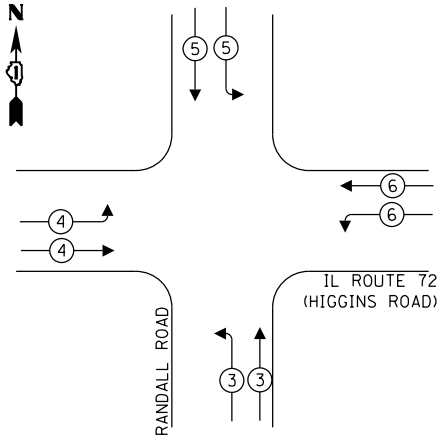

TRAFFIC SIGNAL ELECTRICAL SERVICE REQUIREMENTS

EQUIPMENT TYPE	QUANTITY	UNIT WATTAGE	TOTAL WATTAGE
SIGNAL HEAD 1 OR 3-SECTION	18	11	198
4-SECTION	0	14	0
5-SECTION	0	13	0
PROGRAMMABLE 3-SECTION	0	22	0
4-SECTION	0	32	0
5-SECTION	0	28	0
PEDESTRIAN SIGNAL	0	15	0
CONTROLLER	1	150	150
MASTER CONTROLLER	0	100	0
UPS	1	25	25
DETECTION RADAR OR VIDEO	4	20	80
BLANK-OUT SIGN	0	25	0
NETWORK SWITCH II OR III	1	35	35
CELLULAR MODEM	0	15	0
PTZ CAMERA	1	75	75
TOTAL UPS SIZING			563
UPS CHARGING	1	225	225
BATTERY HEATER MAT	1	180	180
CABINET HEATER	1	200	200
FLASHER	0	15	0
LED STREET NAME SIGN	0	120	0
LUMINAIRE	0	240	0
TOTAL SERVICE WIRE SIZING			1,168

ENERGY COSTS TO:

ILLINOIS DEPARTMENT OF TRANSPORTATION
201 W CENTER COURT
SCHAUMBURG, IL 60196


ENERGY SUPPLY: CONTACT: CASSIE EVANS

PHONE: 773-241-0741

COMPANY: COMED

ACCOUNT NUMBER: 2602829000

METER NUMBER: ---

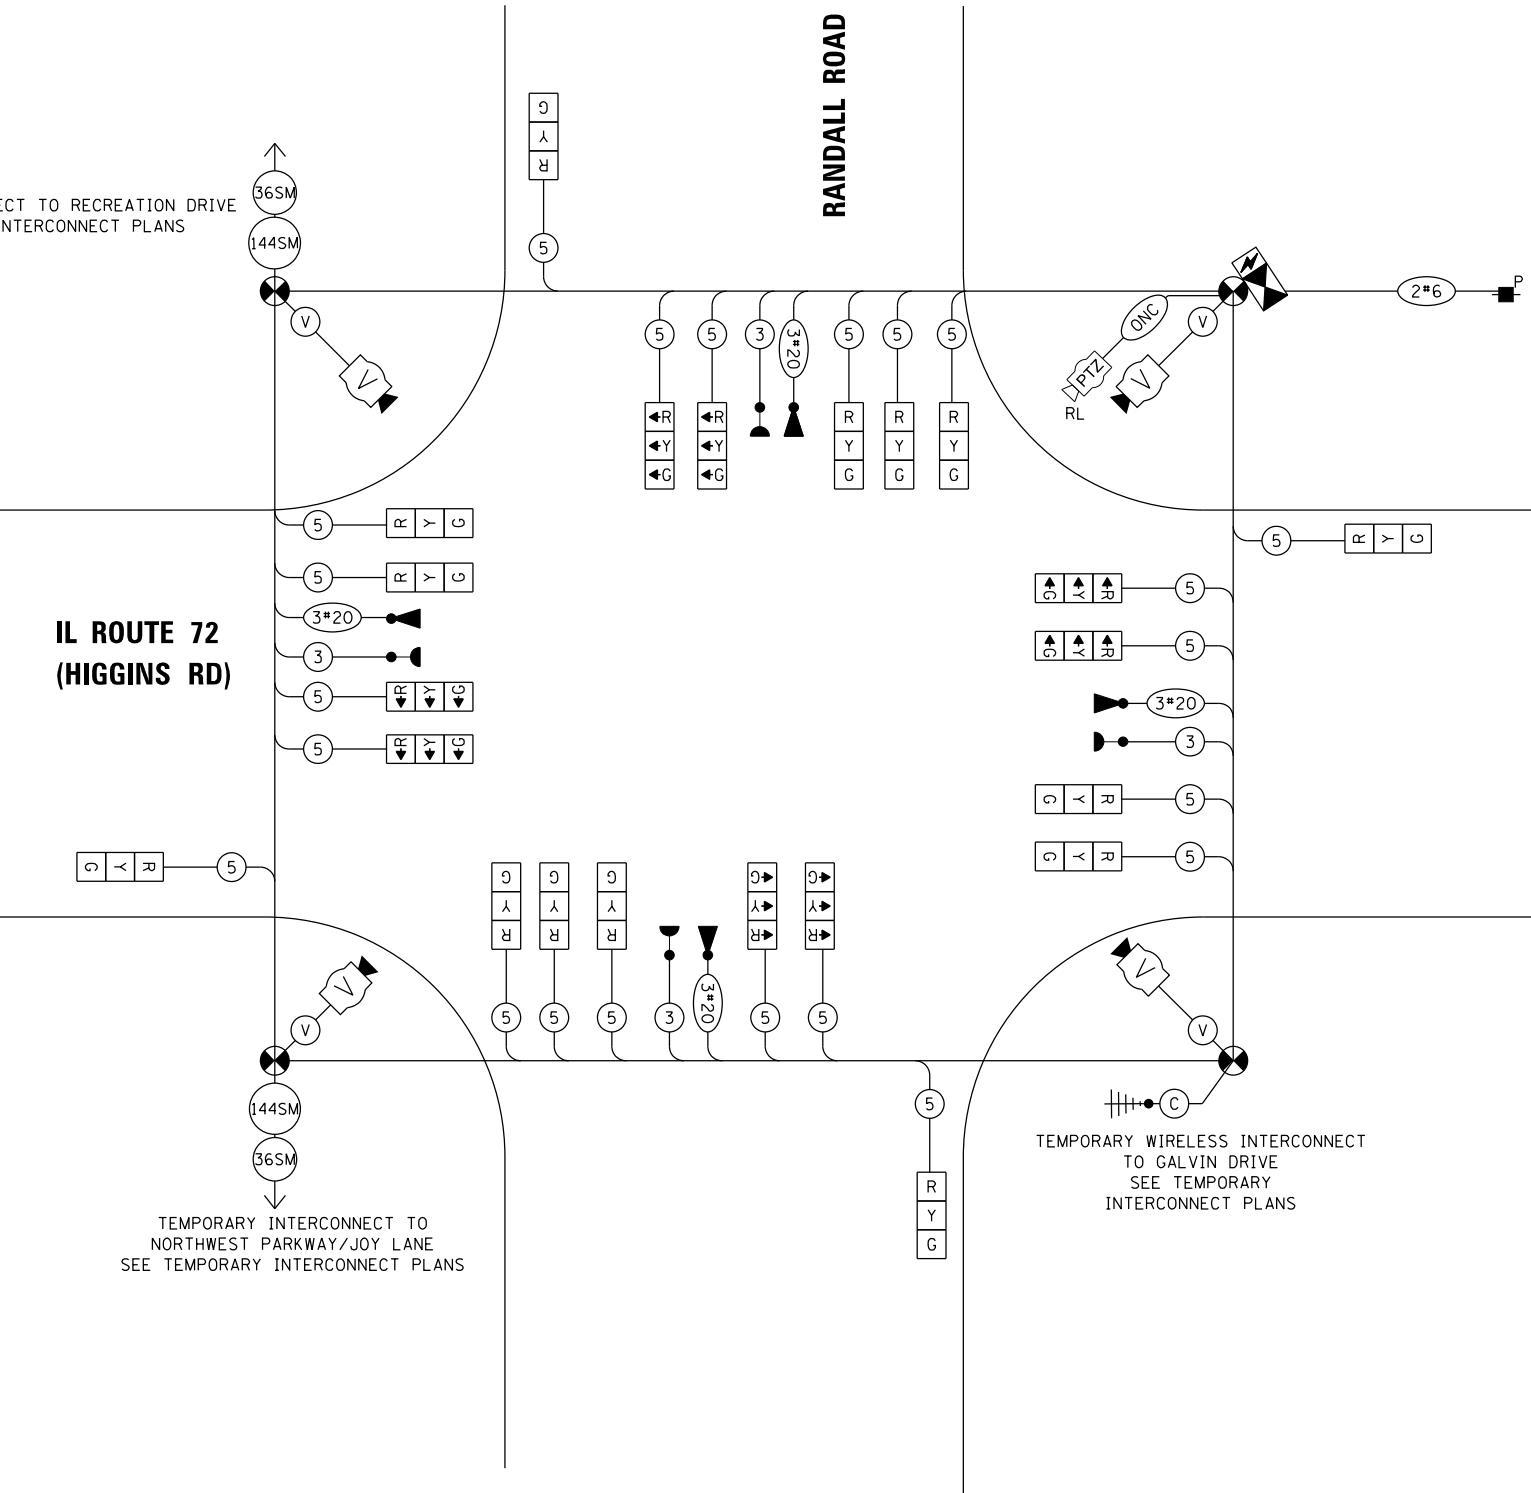

TEMPORARY CABLE PLAN

(NOT TO SCALE)

TS 812
FL 762
FL 763
KDOT SYSTEM

STATE OF ILLINOIS
DEPARTMENT OF TRANSPORTATION

ALL STAGES TEMPORARY CABLE PLAN, TEMPORARY PHASE DESIGNATION
DIAGRAM AND TEMPORARY EMERGENCY VEHICLE PREEMPTION SEQUENCE
RANDALL ROAD AT IL ROUTE 72 (HIGGINS ROAD)


SCALE: NTS SHEET 7 OF 7 SHEETS STA. N/A TO STA. N/A

F.A.P. RTE.	SECTION	COUNTY	TOTAL SHEETS	SHEET NO.
0336	19-00514-00-WR	KANE	304	174
CONTRACT NO. 61L28				
ILLINOIS FED. AID PROJECT				

MODEL: D:\dtd\11\110304-088 Randall at Higgins Phase II Engineering\CAD\DD_Sheets\018 Traffic Signals\19-00514-00-WR_SHT_TEMP_Traffic Signals_001.dgn
FILE NAME: 19-00514-00-WR Randall at Higgins Phase II Engineering\CAD\DD_Sheets\018 Traffic Signals\19-00514-00-WR_SHT_TEMP_Traffic Signals_001.dgn



USER NAME : tnestor	DESIGNED - TN	REVISED -
PLOT SCALE : 40.0000' / in.	DRAWN - TN	REVISED -
PLOT DATE : 8/21/2025	CHECKED - GJE	REVISED -
	DATE - 02/15/2025	REVISED -


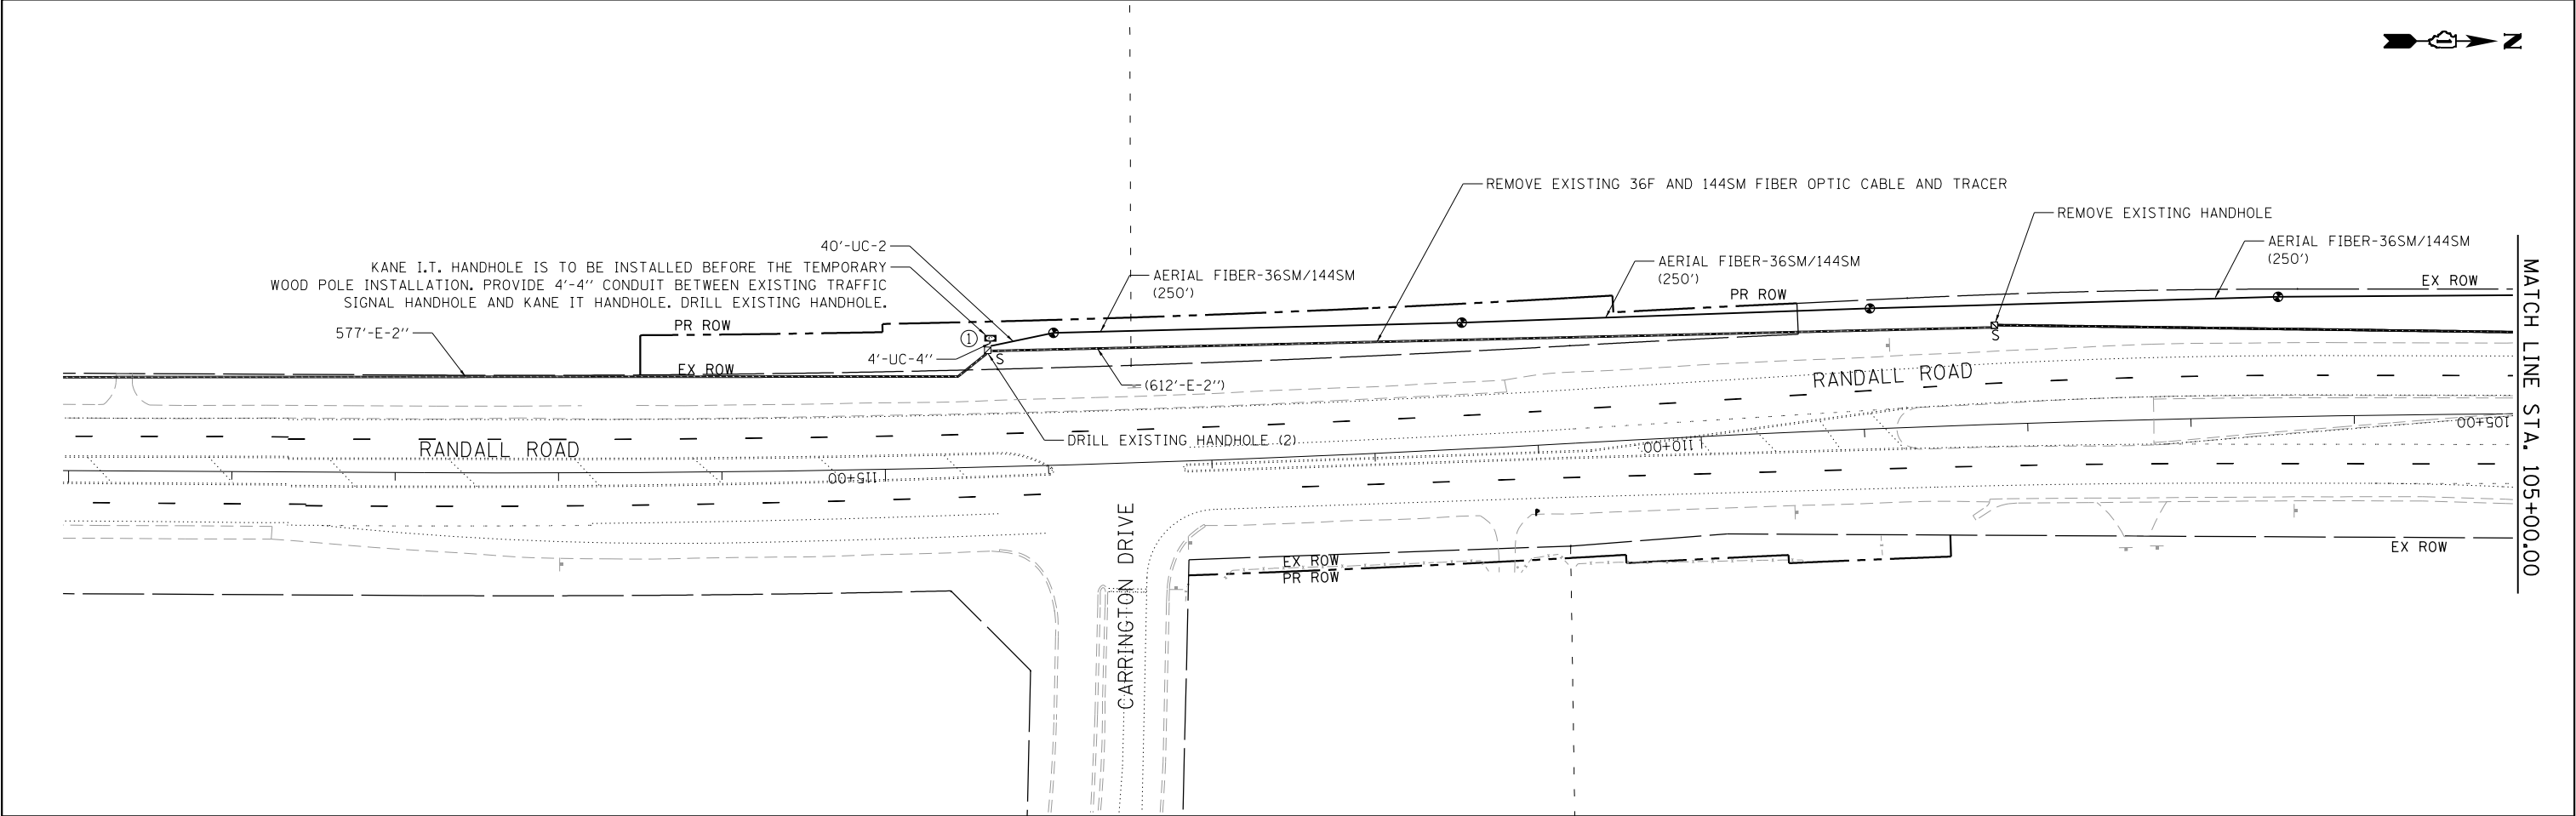


- ① CONSTRUCTION NOTES:
- BUILD PROPOSED KANE IT HANDHOLE BEFORE ANY WORK FOR TEMPORARY TRAFFIC SIGNAL INTERCONNECT. PULL EXISTING 144F FIBER CABLE FROM THE INTERSECTION OF RANDALL ROAD AT IL ROUTE 72 TO THE HANDHOLE AT 114+50 AND STORE IN THIS HANDHOLE. THE CONTRACTOR SHALL THEN SPLICE THE EXISTING FIBER OPTIC CABLE TO TEMPORARY FIBER OPTIC CABLE LEADING TO THE TEMPORARY TRAFFIC SIGNAL CONTROLLER CABINET. THE CABLE SPLICES SHALL BE ABOVE GROUND IN A WEATHERPROOF ENCLOSURE MOUNTED ON THE WOOD POLE IN A WORKMANLIKE MANNER. CONTRACTOR SHALL COORDINATE WITH KANE IT AND KANE IT FIBER CABLE CONTRACTOR NTI AT LEBOKURT@KANECOUNTYIL.GOV AND ATNSCHROEDER@NTITECH.COM FOR THE 144SM FIBER SPLICE AND TERMINATION. THIS THIS WORK SHALL BE INCLUDED IN THE CONTRACT UNIT PRICE FOR "TEMPORARY INTERCONNECT."
- PULL EXISTING 36F FIBER CABLE FROM THE INTERSECTION OF RANDALL ROAD AT IL ROUTE 72 TO THE HANDHOLE AT 114+50 AND STORE IN THIS HANDHOLE. THE CONTRACTOR SHALL THEN SPLICE THE EXISTING FIBER OPTIC CABLE TO TEMPORARY FIBER OPTIC CABLE LEADING TO THE TEMPORARY TRAFFIC SIGNAL CONTROLLER CABINET. THE CABLE SPLICES SHALL BE ABOVE GROUND IN A WEATHERPROOF ENCLOSURE MOUNTED ON THE WOOD POLE IN A WORKMANLIKE MANNER. THIS THIS WORK SHALL BE INCLUDED IN THE CONTRACT UNIT PRICE FOR "TEMPORARY INTERCONNECT."
- EXISTING INTERCONNECT TRACER CABLE TO BE PULLED BACK TO THE LIMITS ABOVE. ITS REMOVAL TO BE PAID FOR AS "REMOVE ELECTRICAL CABLE FROM CONDUIT."

MODEL: Default
FILE NAME: W:\894988_Randall at Higgins_Phase II Engineering\CADD_Sheets\016_Traffic Signals\940514-00-WR_SHT_TEMP_Interconnect Plan 01.dgn



 KANE I.T. HH 36"X60"X36" WITH TIER,
LABEL: "KANE INFORMATION TECHNOLOGY"
WITH 1-4" CONDUIT TO TRAFFIC SIGNAL HH.

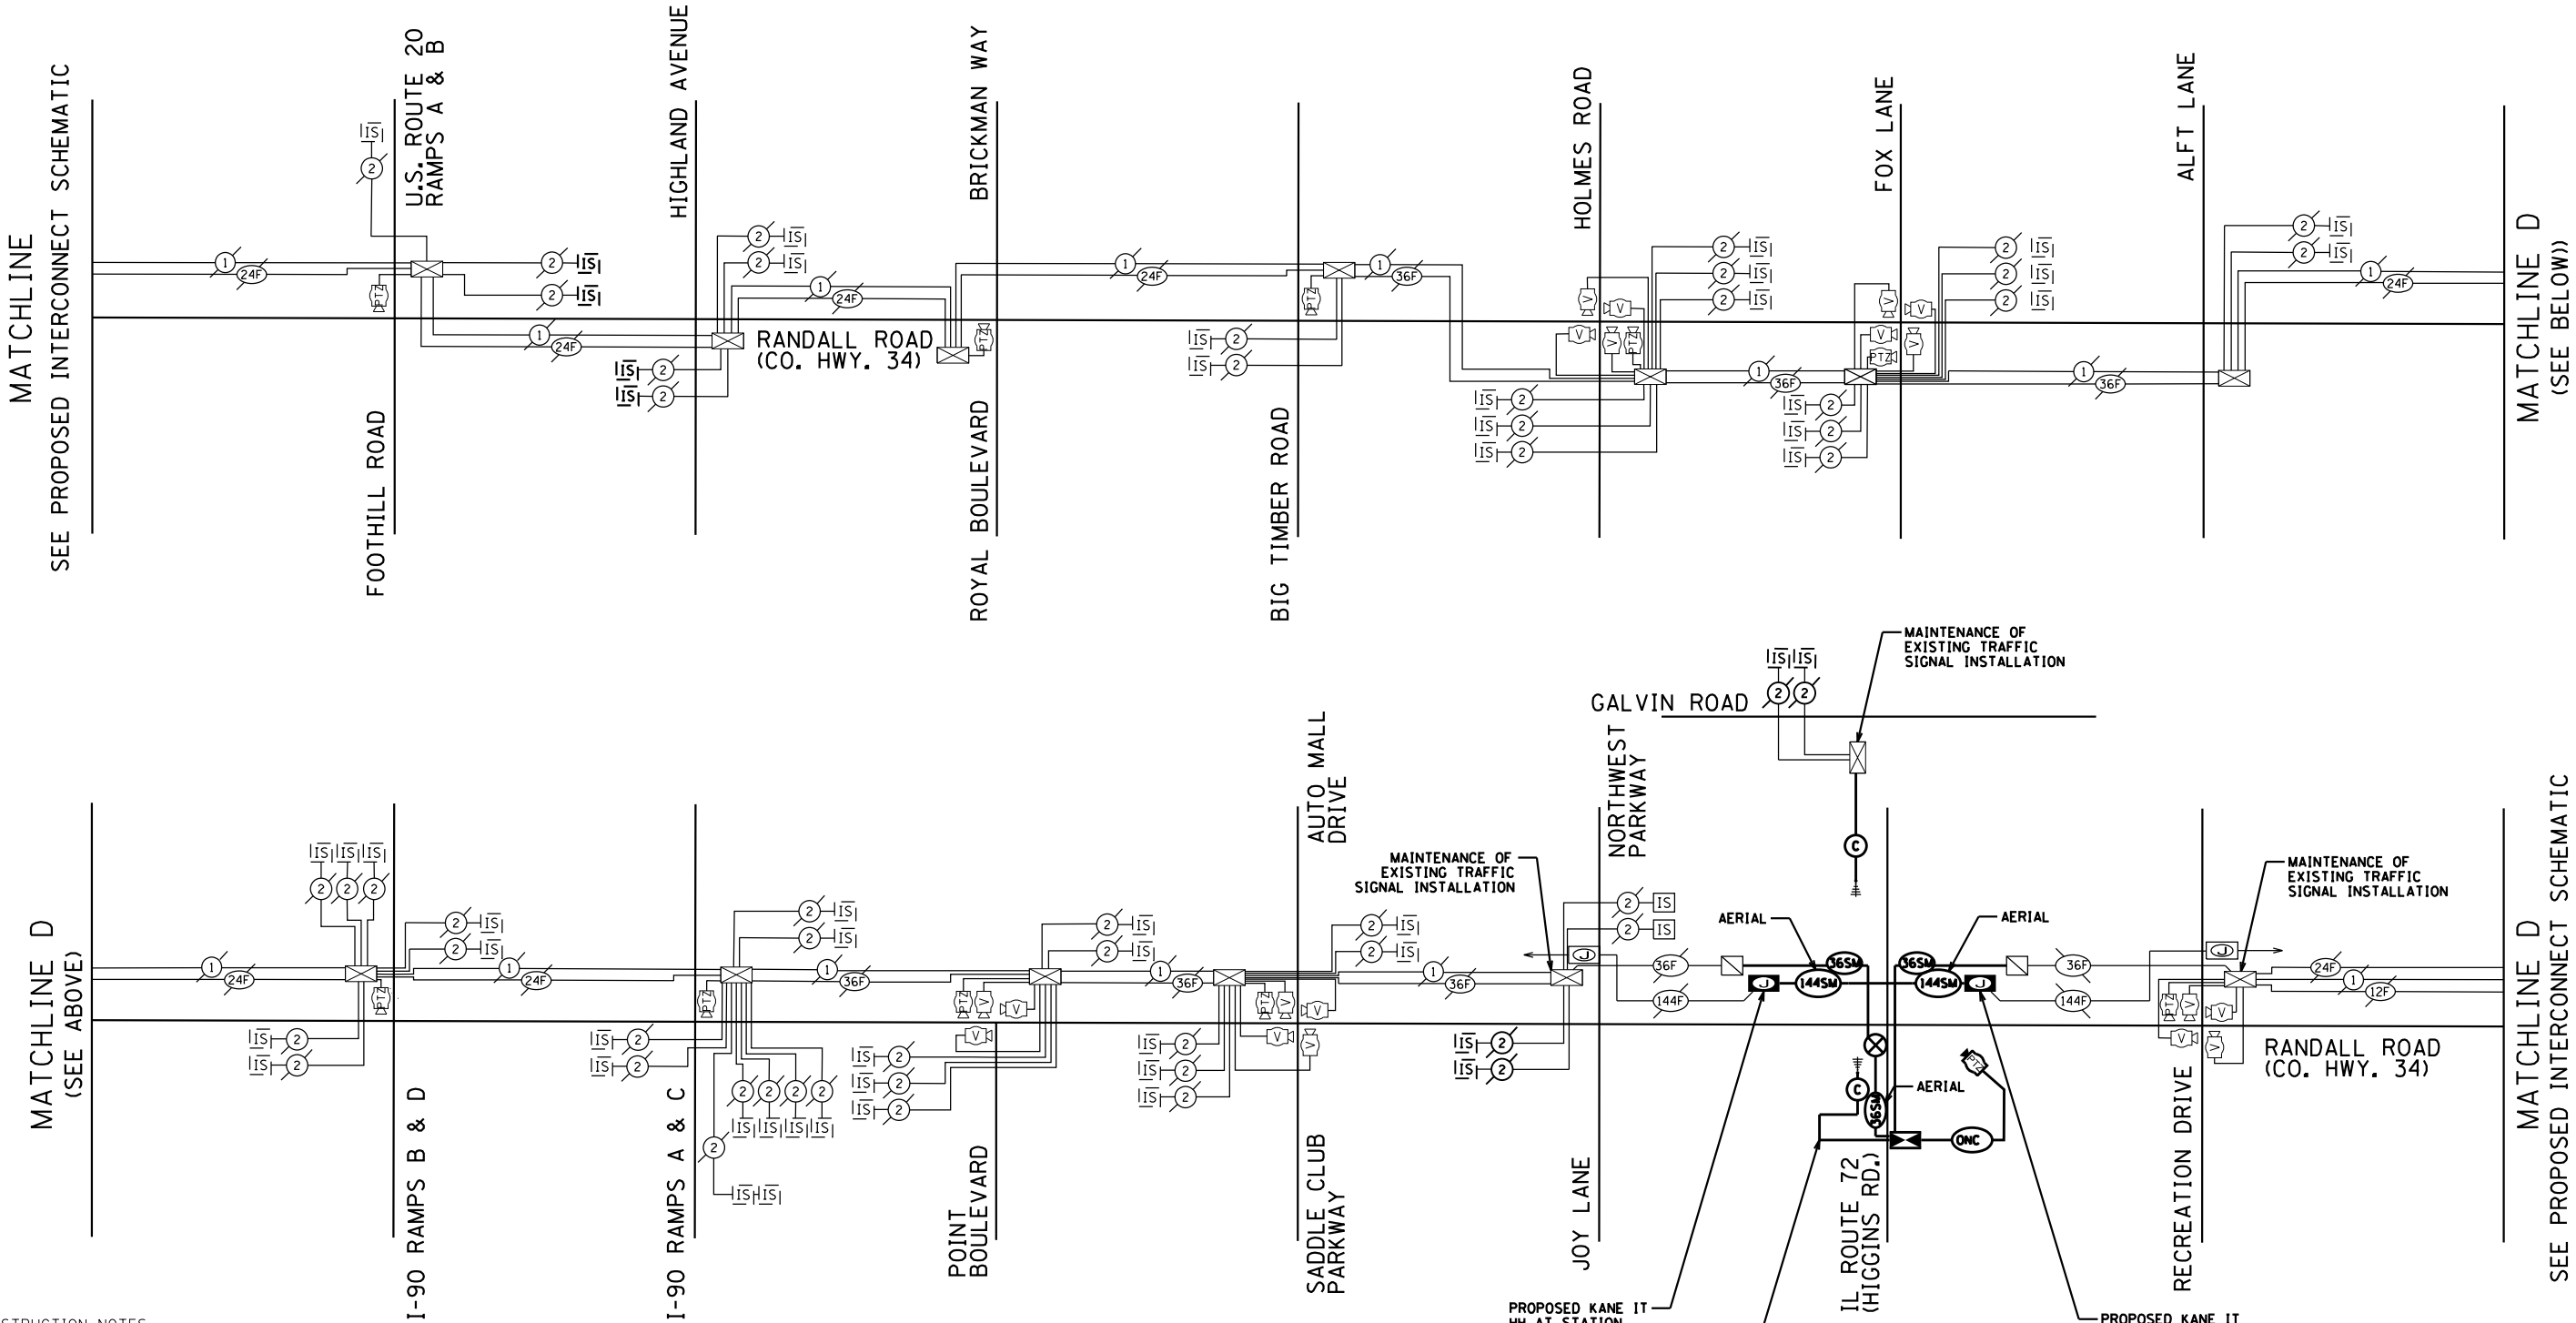

CONSTRUCTION NOTES:
BUILD PROPOSED KANE IT HANDHOLE BEFORE ANY WORK FOR TEMPORARY TRAFFIC SIGNAL INTERCONNECT. PULL EXISTING 144F FIBER CABLE FROM THE INTERSECTION OF RANDALL ROAD AT IL ROUTE 72 TO THE HANDHOLE AT 85+50 AND 114+50 AND STORE IN THIS HANDHOLE. THE CONTRACTOR SHALL THEN SPLICE THE EXISTING FIBER OPTIC CABLE TO TEMPORARY FIBER OPTIC CABLE LEADING TO THE TEMPORARY TRAFFIC SIGNAL CONTROLLER CABINET. THE CABLE SPLICES SHALL BE ABOVE GROUND IN A WEATHERPROOF ENCLOSURE MOUNTED ON THE WOOD POLE IN A WORKMANLIKE MANNER. CONTRACTOR SHALL COORDINATE WITH KANE IT AND KANE IT FIBER CABLE CONTRACTOR NTI AT LEBOKURT@KANECOUNTYIL.GOV AND ATNSCHROEDER@NTITECH.COM FOR THE 144F FIBER SPLICE AND TERMINATION. THIS THIS WORK SHALL BE INCLUDED IN THE CONTRACT UNIT PRICE FOR "TEMPORARY INTERCONNECT."

PULL EXISTING 36SM FIBER CABLE FROM THE INTERSECTION OF RANDALL ROAD AT IL ROUTE 72 TO THE HANDHOLE AT 85+50 AND 114+50 AND STORE IN THIS HANDHOLE. THE CONTRACTOR SHALL THEN SPLICE THE EXISTING FIBER OPTIC CABLE TO TEMPORARY FIBER OPTIC CABLE LEADING TO THE TEMPORARY TRAFFIC SIGNAL CONTROLLER CABINET. THE CABLE SPLICES SHALL BE ABOVE GROUND IN A WEATHERPROOF ENCLOSURE MOUNTED ON THE WOOD POLE IN A WORKMANLIKE MANNER. THIS THIS WORK SHALL BE INCLUDED IN THE CONTRACT UNIT PRICE FOR "TEMPORARY INTERCONNECT."

EXISTING INTERCONNECT TRACER CABLE REMOVAL TO BE PAID FOR AS "REMOVE ELECTRICAL CABLE FROM CONDUIT."

PROPOSED KANE IT
HH AT STATION
85+50
SEE NOTE 1.

WIRELESS INTERCONNECT
SYSTEM SHALL BE CAPABLE
OF WIRELESS BACKHAUL
WITH VLANS INTERFACING
WITH EXISTING SWITCH
HARDWARE

MAINTENANCE OF
EXISTING TRAFFIC
SIGNAL INSTALLATION

MAINTENANCE OF
EXISTING TRAFFIC
SIGNAL INSTALLATION

MAINTENANCE OF
EXISTING TRAFFIC
SIGNAL INSTALLATION

PROPOSED KANE IT
HH AT STATION
114+50
SEE NOTE 1.



BLA, Inc.

USER NAME = tnestor	DESIGNED - TN	REVISED -
PLOT SCALE = 100.0000' / in.	DRAWN - TN	REVISED -
PLOT DATE = 8/21/2025	CHECKED - GJE	REVISED -
	DATE - 02/15/2025	REVISED -

STATE OF ILLINOIS
DEPARTMENT OF TRANSPORTATION

RANDALL ROAD AT IL ROUTE 72 (HIGGINS ROAD)
TEMP INTERCONNECT SCHEMATIC

SCALE: NTS SHEET 1 OF 1 SHEETS STA. N/A TO STA. N/A

F.A.P. RTE.	SECTION	COUNTY	TOTAL SHEETS	SHEET NO.
0336	19-00514-00-WR	KANE	304	177
CONTRACT NO. 61L28				
ILLINOIS FED. AID PROJECT				

KDOT SYSTEM

MODEL: Default
FILE NAME: W:\894-088 Randall at Higgins Phase II Engineering\CADD Sheets\016 Traffic Signals\19-00514-00-WR_SHT_Signal_TEMP NOTES.dgn

TEMPORARY TRAFFIC SIGNAL NOTES

- ALL CONTROL EQUIPMENT INCLUDING EMERGENCY PRE-EMPTION AND COMMUNICATION DEVICES FOR THE TEMPORARY TRAFFIC SIGNAL(S) SHALL BE FURNISHED BY THE CONTRACTOR WHICH THE EXCEPTION OF THE EXISTING LAYER 2 SWITCH WHICH IS TO BE RELOCATED TO THE TEMPORARY SIGNAL.
- ONLY CONTROLLERS SUPPLIED BY ONE OF THE DISTRICT APPROVED CLOSED LOOP EQUIPMENT MANUFACTURES WILL BE APPROVED FOR USE AT TEMPORARY SIGNALS LOCATIONS. ALL CONTROLLERS USED FOR TEMPORARY TRAFFIC SIGNALS SHALL BE FULLY ACTUATED NEMA MICROPROCESSOR BASED WITH RS232 DATA ENTRY PORTS COMPATIBLE WITH EXISTING MONITORING SOFTWARE APPROVED BY IDOT DISTRICT 1, INSTALLED IN A NEMA TS2 CABINET. ONLY ONE BRAND OF CONTROLLER CABINET TO THE SIGNAL HEAD.
- ALL TRAFFIC SIGNAL SECTIONS AND PEDESTRIAN SIGNAL SECTIONS SHALL BE 12" (300MM). HEADS SHALL BE PLACED AS INDICATED ON THE TEMPORARY TRAFFIC SIGNAL PLAN OR AS DIRECTED BY THE ENGINEER. THE CONTRACTOR SHALL FURNISH ENOUGH CABLE SLACK TO RELOCATE HEADS TO ANY POSITION ON THE SPAN WIRE OR AT LOCATIONS ILLUSTRATED ON THE PLANS FOR CONSTRUCTION STAGING. THE TEMPORARY TRAFFIC SIGNAL SHALL REMAIN IN OPERATION DURING ALL SIGNAL HEAD RELOCATIONS. EACH TEMPORARY TRAFFIC SIGNAL HEAD SHALL HAVE ITS OWN CABLE FROM THE CONTROLLER CABINET TO THE SIGNAL HEAD.
- ALL EXISTING STREET NAME AND INTERSECTION REGULATORY SIGNS SHALL BE REMOVED FROM EXISTING POLES, RELOCATED AND SECURELY FASTENED TO THE SIGNAL SPAN WIRE OR WOOD POLE AS DIRECTED BY THE ENGINEER.
- THE TEMPORARY TRAFFIC SIGNAL SHALL HAVE THE SIGNAL HEAD DISPLAYS, SIGNAL HEAD PLACEMENTS AND CONTROLLER PHASING MATCH THE EXISTING TRAFFIC SIGNAL, AT THE TIME OF THE TURN ON, IF NO TRAFFIC STAGING IS IN PLACE OR WILL NOT BE STAGED ON THE DAY OF THE TURN ON.
- UNINTERRUPTIBLE POWER SUPPLY (UPS) SYSTEMS SHALL BE INSTALLED AND MADE OPERATIONAL AT TEMPORARY TRAFFIC SIGNAL INSTALLATIONS WHERE UPS IS INSTALLED AT THE EXISTING TRAFFIC SIGNALS, TEMPORARY TRAFFIC SIGNALS AT RAILROADS INTERSECTIONS, AND TEMPORARY TRAFFIC SIGNALS AT INTERSECTIONS WITH FIRE STATION ACTUATED EMERGENCY VEHICLE PRE-EMPTION, OR WHEN INDICATED ON THE PLANS.
- WHEN PAN, TILT, ZOOM CAMERAS ARE INSTALLED AT THE EXISTING INTERSECTION, RELOCATION OF THE EXISTING PTZ TO TEMPORARY SIGNAL INSTALLATION OR ARE CALLED FOR IN THE PLANS, THE CONTRACTOR SHALL BE RESPONSIBLE FOR INSTALLING AND MAINTAINING THE CAMERAS TO THE SATISFACTION OF THE ENGINEER AND THE AGENCY RESPONSIBLE FOR THE CAMERAS.
- TRAFFIC SIGNAL MANAGEMENT SYSTEMS SHALL BE MAINTAINED IN OPERATION AS INDICATED ON THE PLANS OR AS DIRECTED BY THE ENGINEER. REQUIRED EQUIPMENT SHALL BE SHOWN ON THE PLANS AND THE CONTRACTOR SHALL PLACE THE EQUIPMENT IN OPERATION TO THE SATISFACTION OF THE ENGINEER AND THE AGENCY RESPONSIBLE FOR THE TRAFFIC SIGNAL MANAGEMENT SYSTEM.
- DETECTION AT TEMPORARY TRAFFIC SIGNALS SHALL BE INCLUDED FOR APPROACHES OF THE INTERSECTION UNLESS INDICATED OTHERWISE ON THE PLANS. THE DETECTION SYSTEM MUST MEET THE SPECIFICATIONS OF DISTRICT 1 AND THE CONTRACTOR SHALL PLACE THE DETECTORS INTO OPERATION TO THE SATISFACTION OF THE ENGINEER.
- ANY TEMPORARY TRAFFIC SECTIONS NOT IN USE DURING A STAGE OF CONSTRUCTION SHALL BE BAGGED AND DEACTIVATED. ALL PERMANENT TRAFFIC SIGNAL SECTIONS SHALL BE BAGGED OR REMOVED WHILE THE TEMPORARY TRAFFIC SIGNAL IS OPERATION. ALL VIDEO DETECTION ZONES ARE TO BE REDEFINED DURING EACH STAGE OF CONSTRUCTION AND ARE INCLUDED IN THE COST OF THE TEMPORARY TRAFFIC SIGNAL INSTALLATION.
- THE CONTRACTOR MUST PROVIDE ASSURANCE THAT THE RADIO DEVICE WILL OPERATE PROPERLY AT ALL TIMES AND DURING ALL CONSTRUCTION STAGES. IF WIRELESS INTERCONNECT FAILS DURING TESTING OR OPERATION, CONTRACTOR SHALL BE RESPONSIBLE FOR INSTALLING NECESSARY POLES, FIBER OPTIC CABLE AND OTHER INFRASTRUCTURE FOR PROVIDING TEMPORARY FIBER INTERCONNECT AT NO COST TO THE CONTRACT.
- IT IS THE CONTRACTOR'S RESPONSIBILITY TO COORDINATE WITH AND COMPENSATE KANE COUNTY'S FIBER OPTIC CONTRACTOR-NTI NATIONAL TECHNOLOGIES, WHICH INCLUDE ALL TIME, MATERIAL, SPLICES AND TERMINATION ASSIGNMENTS WITH KANE COUNTY'S FIBER OPTIC CONTRACTOR TO MAKE THE TEMPORARY KANE IT INTERCONNECT OR AS OUTLINED IN THE PLANS OR SPECIFICATIONS.
- CONTRACTOR SHALL COORDINATE WITH KANE IT AND KANE IT FIBER CABLE CONTRACTOR NTI AT LEBORKURT@KANECOUNTYIL.GOV AND ATNSCHROEDER@NTITECH.COM FOR THE FIBER SPLICING AND TERMINATION.



BLA, Inc.


USER NAME = tnestor	DESIGNED - TN	REVISED -
	DRAWN - TN	REVISED -
PLOT SCALE = 2.0000" = 1 in.	CHECKED - GJE	REVISED -
PLOT DATE = 8/21/2025	DATE - 02/15/2025	REVISED -

STATE OF ILLINOIS
DEPARTMENT OF TRANSPORTATION

RANDALL ROAD AT IL ROUTE 72 (HIGGINS ROAD)
TEMPORARY TRAFFIC SIGNAL NOTES

SCALE: N/A SHEET 1 OF 1 SHEETS STA. N/A TO STA. N/A

F.A.P. RTE.	SECTION	COUNTY	TOTAL SHEETS	SHEET NO.
0336	19-00514-00-WR	KANE	304	178
CONTRACT NO. 61L28				
ILLINOIS FED. AID PROJECT				

 

RANDALL ROAD (SEE SHEET 183)
MATCH LINE STA. 98+00.00




MAIL ROUTE 72 (HIGGINS ROAD) (SEE SHEET 182)
MATCH LINE STA. 197+00.00

MATCH LINE 203+00.00
IL ROUTE 72 (HIGGINS ROAD) (SEE SHEET 182)

NOTES:

1. COMBINATION VIDEO/RADAR DETECTORS SHALL BE MOUNTED ON RISER MOUNTS AT OPTIMAL HEIGHT DETERMINED PER MANUFACTURERS RECOMMENDATION.
2. "PUSH BUTTON SHALL BE LESS THAN 10 INCHES TO NEAREST WALKING PATH, PUSH BUTTON EXTENSION SHALL BE LESS THAN 12 INCHES."
3. THE SIDEWALK CURB ON THE SOUTHWEST QUADRANT SHALL BE CUT SO THAT THE POLE FOUNDATION IS FLUSH WITH THE EDGE OF THE SIDEWALK
4. THE LENGTH OF THE LUMINAIRE ARM SHALL BE 15 FEET PER THE HIGHWAY STANDARD

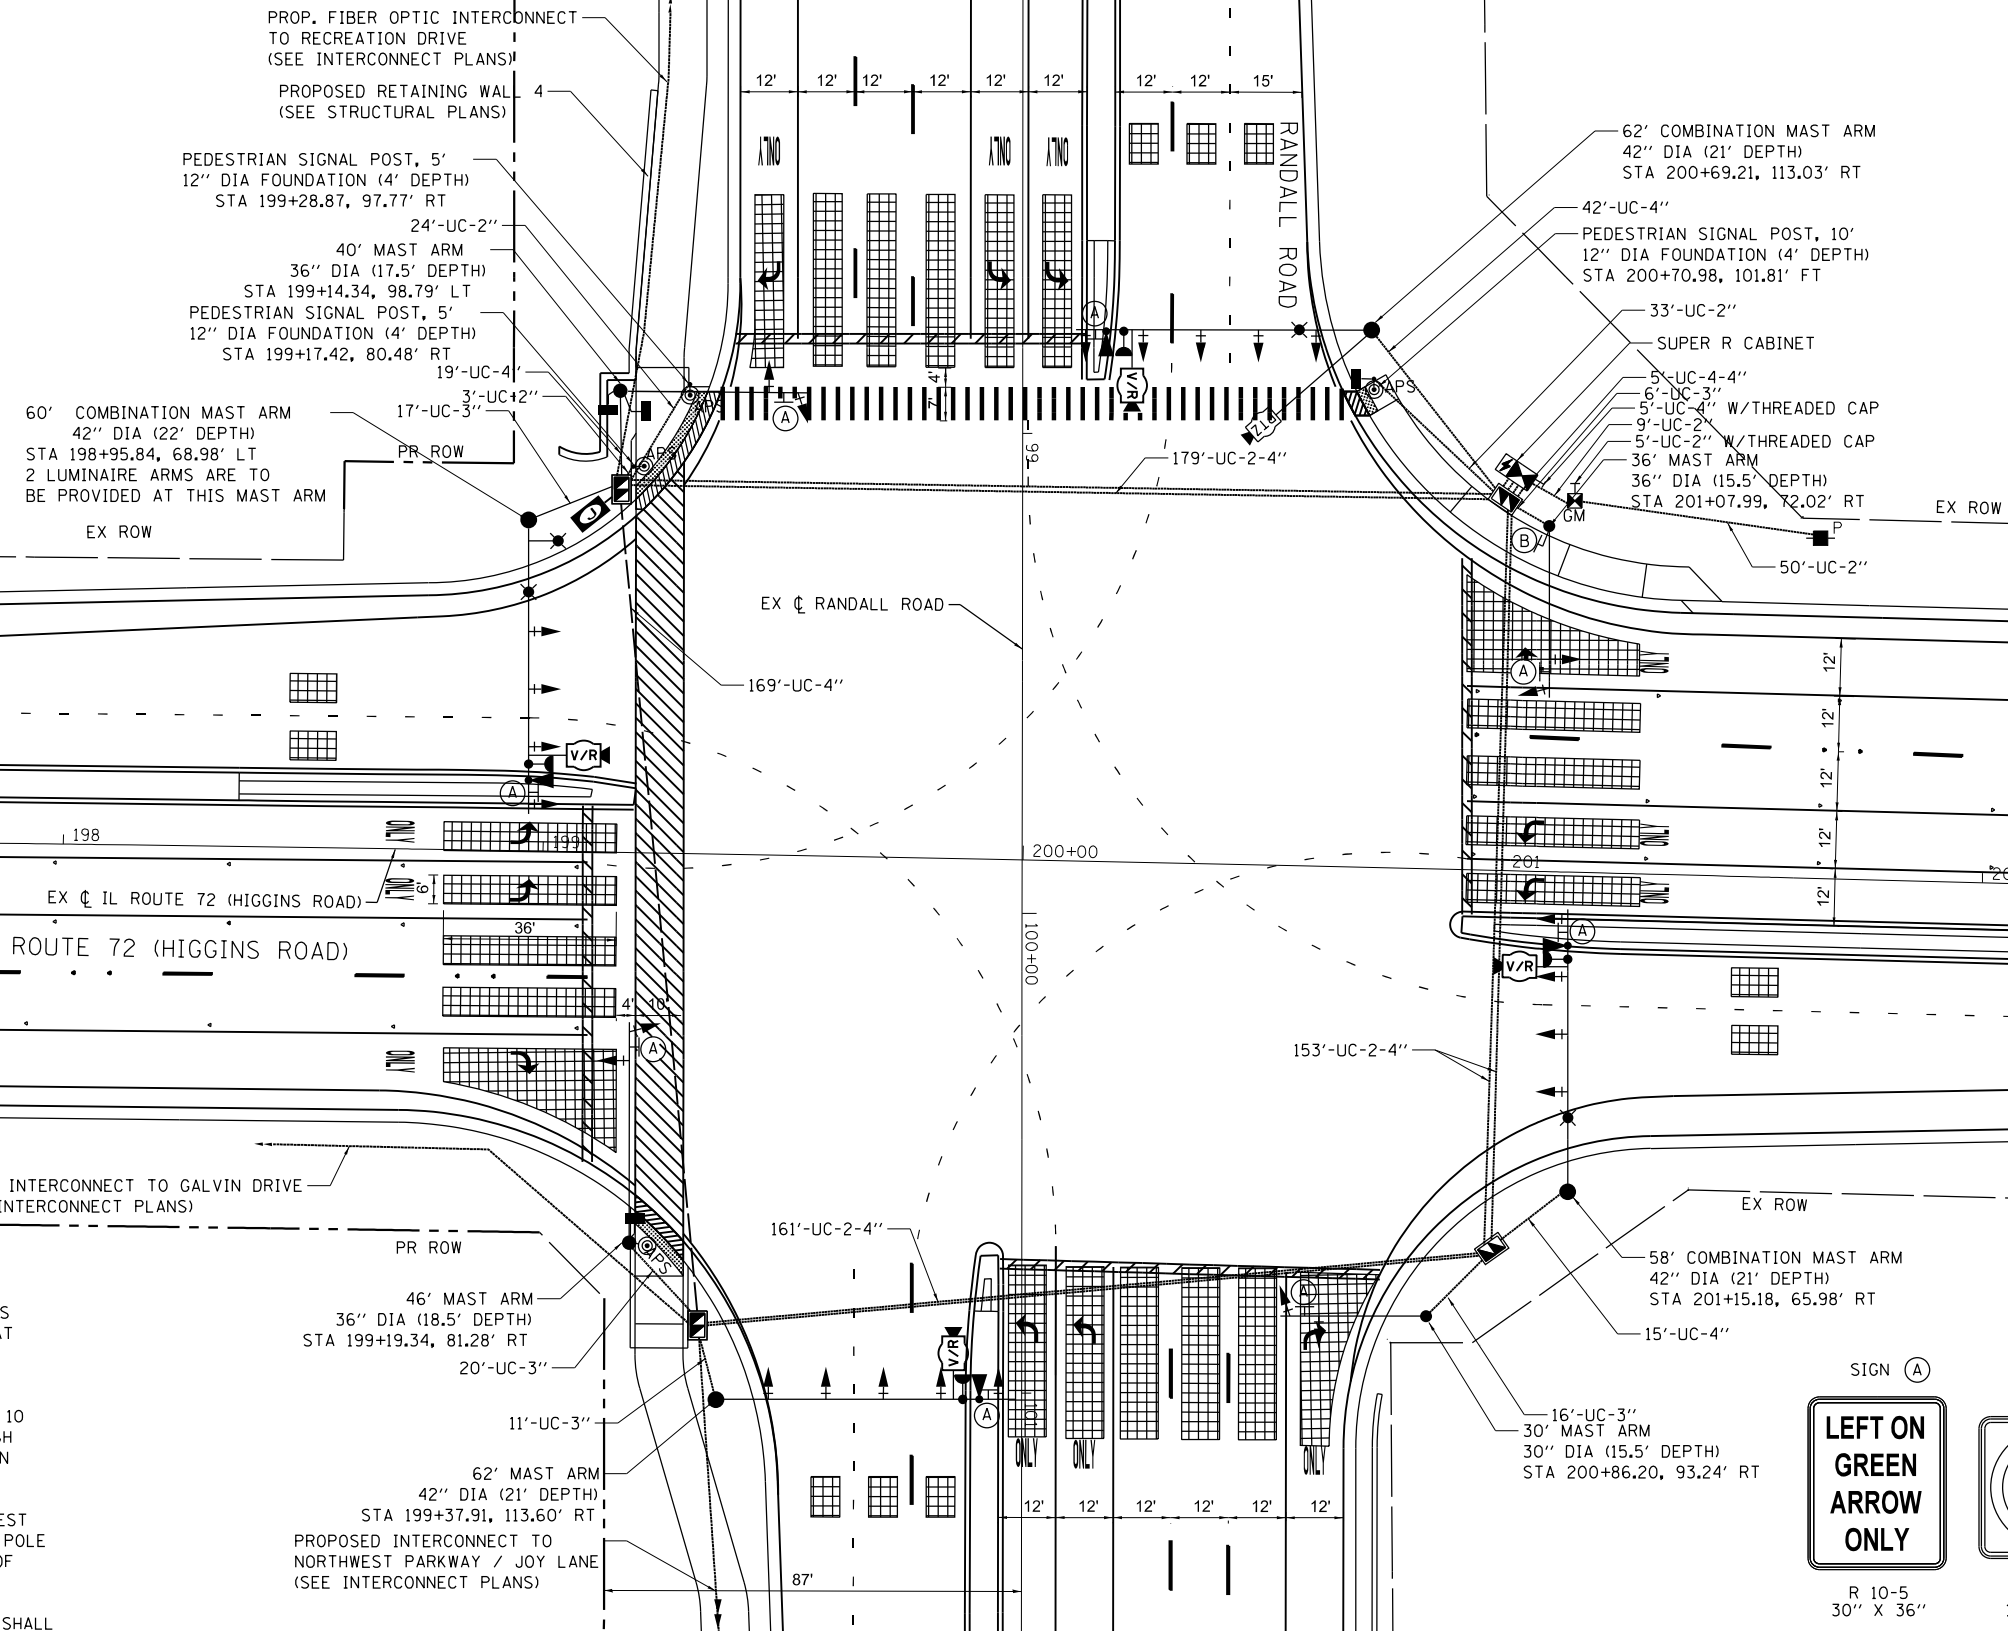

SIGN (A)

LEFT ON
GREEN
ARROW
ONLY

R 10-5
30" X 36"
8 REQUIRED



R9-3a''
18'' X 18''
1 REQUIRED

0 20 40 60
SCALE IN FEET

MATCH LINE STA. 101+50.00
RANDALL ROAD (SEE SHEET 183)

TRAFFIC SIGNAL EQUIPMENT AT THIS INTERSECTION
SHALL BE ECONOLITE TO MATCH THE SIGNAL
EQUIPMENT AT IL ROUTE 72 AND GALVIN ROAD

TS 812
FL 762
FL 763
KDOT SYSTEM



BLA, Inc.




USER NAME = tnestor	DESIGNED = TN	REVISED =
	DRAWN = TN	REVISED =
PLOT SCALE = 40.0000' / in.	CHECKED = GJE	REVISED =
PLOT DATE = 8/21/2025	DATE = 02/15/2025	REVISED =

**STATE OF ILLINOIS
DEPARTMENT OF TRANSPORTATION**

TRAFFIC SIGNAL INSTALLATION PLAN (SHEET 1 OF 3)
RANDALL ROAD AT IL ROUTE 72 (HIGGINS ROAD)

SCALE: 1"=20'	SHEET 1 OF 4 SHEETS	STA. N/A TO STA. N/A
---------------	---------------------	----------------------

F.A.P. RTE.	SECTION	COUNTY	TOTAL SHEETS	SHEET NO.
0336	19-00514-00-WR	KANE	304	179
		CONTRACT NO. 61L28		
ILLINOIS FED. AID PROJECT				

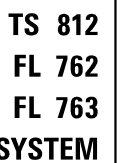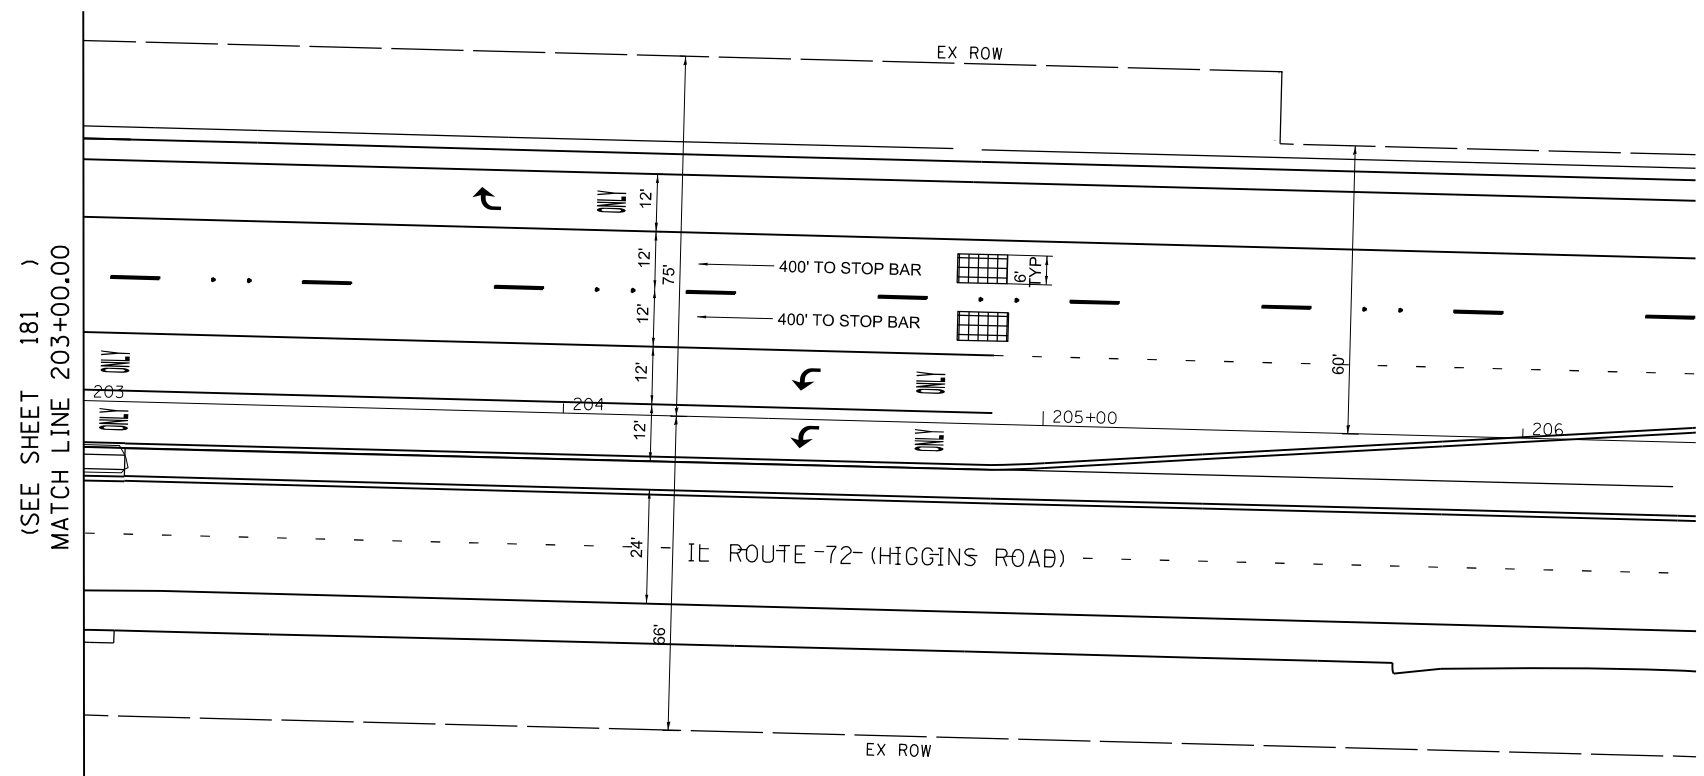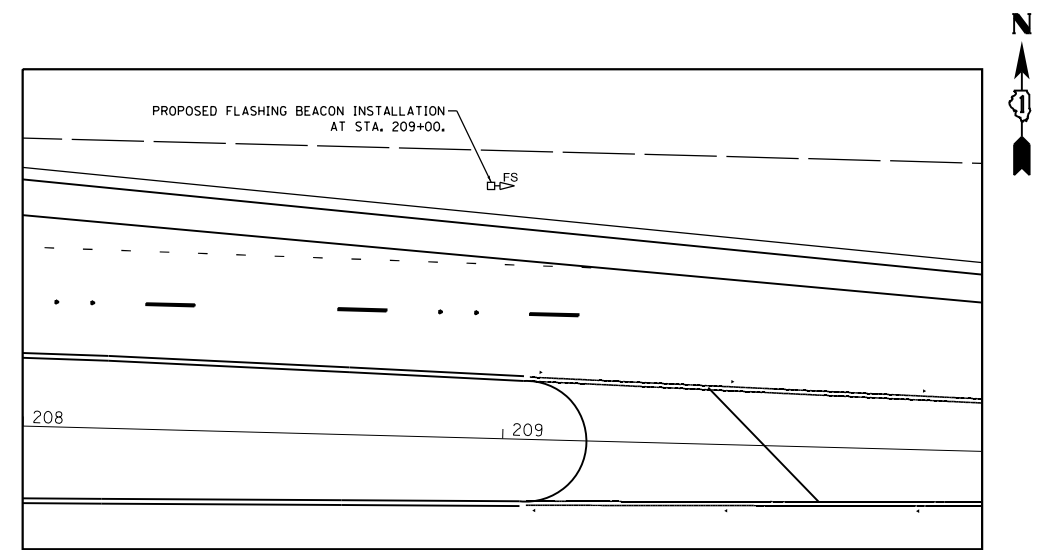


KDOT SYSTEM




TRAFFIC SIGNAL EQUIPMENT AT THIS INTERSECTION
SHALL BE ECONOLITE TO MATCH THE SIGNAL
EQUIPMENT AT IL ROUTE 72 AND GALVIN ROAD

TS 812
FL 762
FL 763
KDOT SYSTEM

(SEE SHEET 181)
MATCH LINE 101+50.00

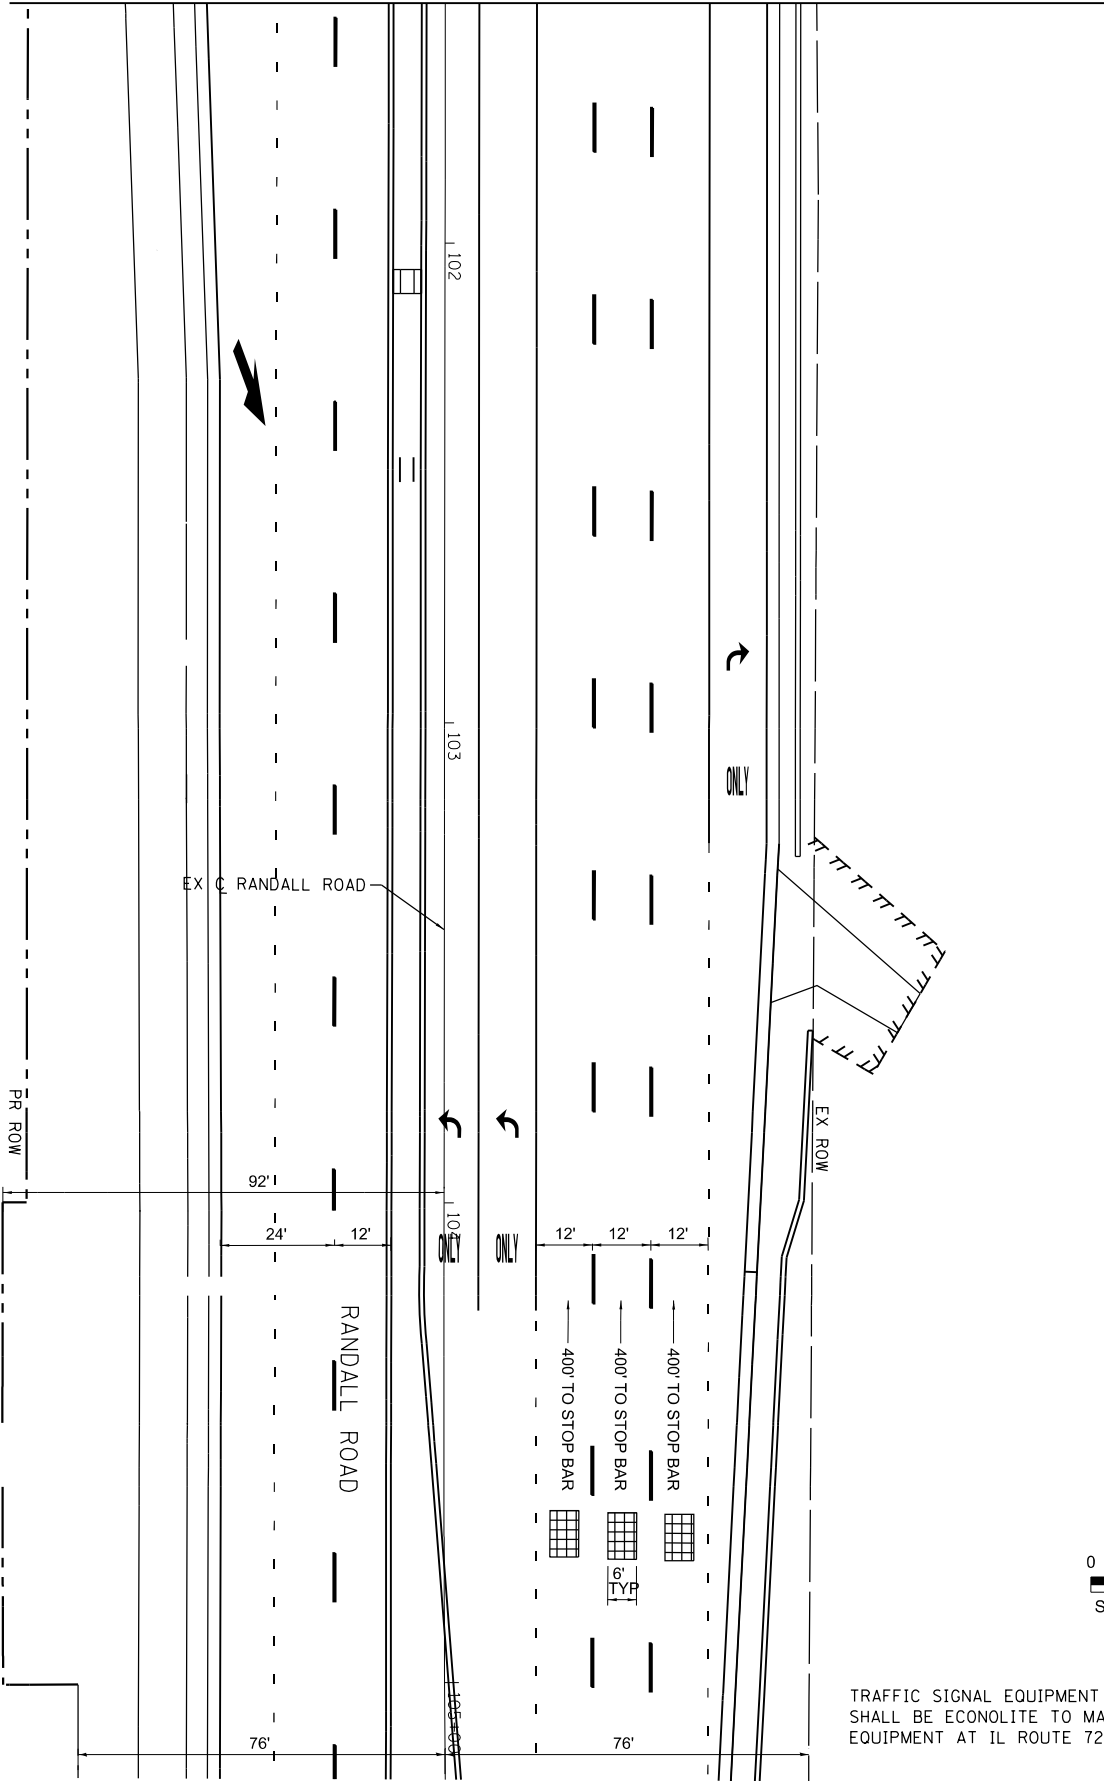

MATCH LINE 98+00.00
(SEE SHEET 181)

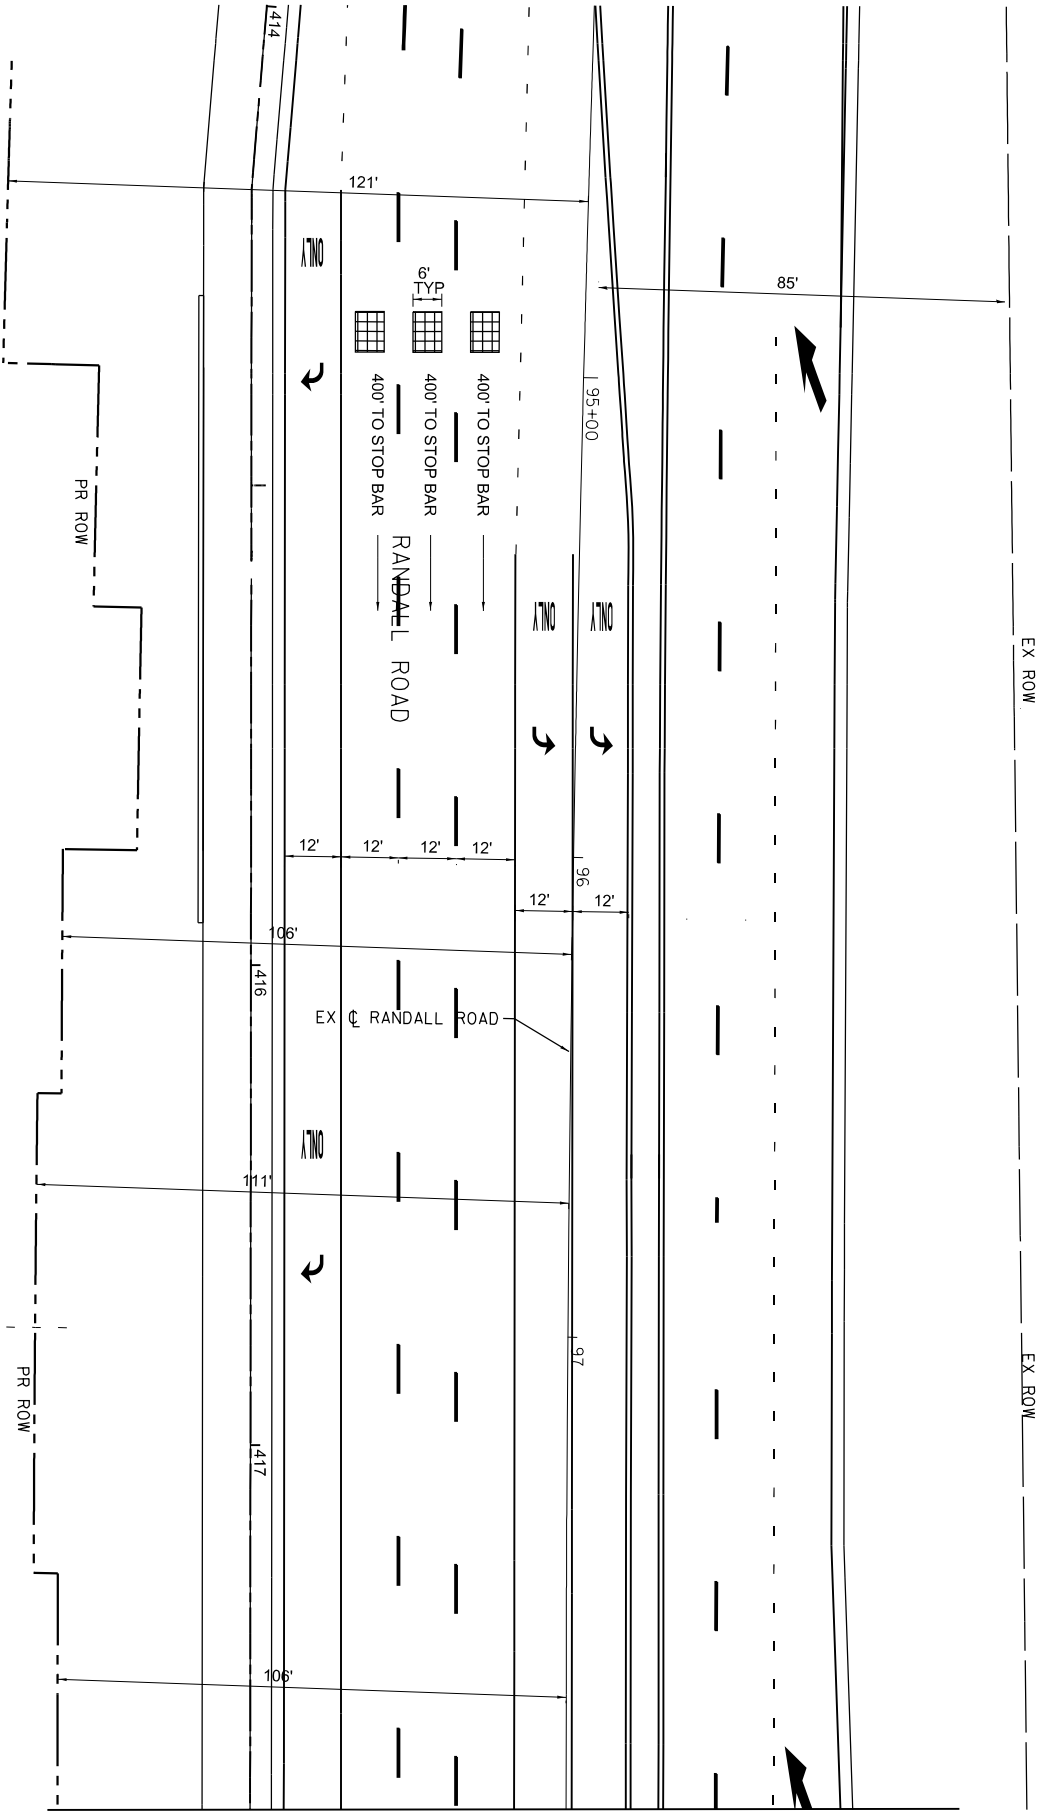




TRAFFIC SIGNAL INSTALLATION PLAN (SHEET 3 OF 3)
RANDALL ROAD AT IL ROUTE 72 (HIGGINS ROAD)

SCALE: 1"=20' SHEET 3 OF 4 SHEETS STA. N/A TO STA. N/A

STATE OF ILLINOIS
DEPARTMENT OF TRANSPORTATION

USER NAME : tnestor	DESIGNED - TN	REVISED -
	DRAWN - TN	REVISED -
PLOT SCALE = 40.0000' / in.	CHECKED - GJE	REVISED -
PLOT DATE = 8/21/2025	DATE - 02/15/2025	REVISED -


F.A.P. RTE.	SECTION	COUNTY	TOTAL SHEETS	SHEET NO.
0336	19-00514-00-WR	KANE	304	181
CONTRACT NO. 61L28				
ILLINOIS FED. AID PROJECT				

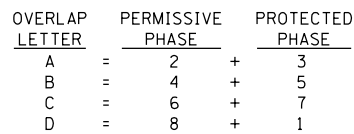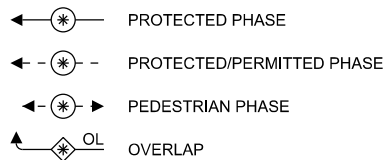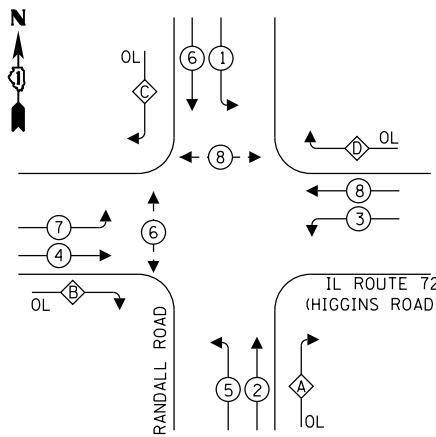

EQUIPMENT TYPE	QUANTITY	UNIT WATTAGE	TOTAL WATTAGE
SIGNAL HEAD 1 OR 3-SECTION	18	11	198
4-SECTION	0	14	0
5-SECTION	8	13	104
PROGRAMMABLE 3-SECTION	0	22	0
4-SECTION	0	32	0
5-SECTION	0	28	0
PEDESTRIAN SIGNAL	4	15	60
CONTROLLER	1	150	150
MASTER CONTROLLER	0	100	0
UPS	1	25	25
DETECTION RADAR OR VIDEO	4	20	80
BLANK-OUT SIGN	0	25	0
NETWORK SWITCH II OR III	1	35	35
CELLULAR MODEM	0	15	0
PTZ CAMERA	1	75	75
TOTAL UPS SIZING			727
UPS CHARGING	1	225	225
BATTERY HEATER MAT	1	180	180
CABINET HEATER	1	200	200
FLASHER	0	15	0
LED STREET NAME SIGN	0	120	0
LUMINAIRE	4	240	960
TOTAL SERVICE WIRE SIZING			2 292

ENERGY COSTS TO:	
ILLINOIS DEPARTMENT OF TRANSPORTATION	
201 W CENTER COURT	
SCHAUMBURG, IL 60196	
ENERGY SUPPLY:	CONTACT: <u>CASSIE EVANS</u>
	PHONE: <u>773-241-0741</u>
	COMPANY: <u>COMED</u>
ACCOUNT NUMBER:	<u>2602829000</u>
METER NUMBER:	<u>--</u>



USER NAME = tnestor	DESIGNED - TN	REVISED -
	DRAWN - TN	REVISED -
PLOT SCALE = 40.0000' / in.	CHECKED - GJE	REVISED -
PLOT DATE = 8/21/2025	DATE - 02/15/2025	REVISED -

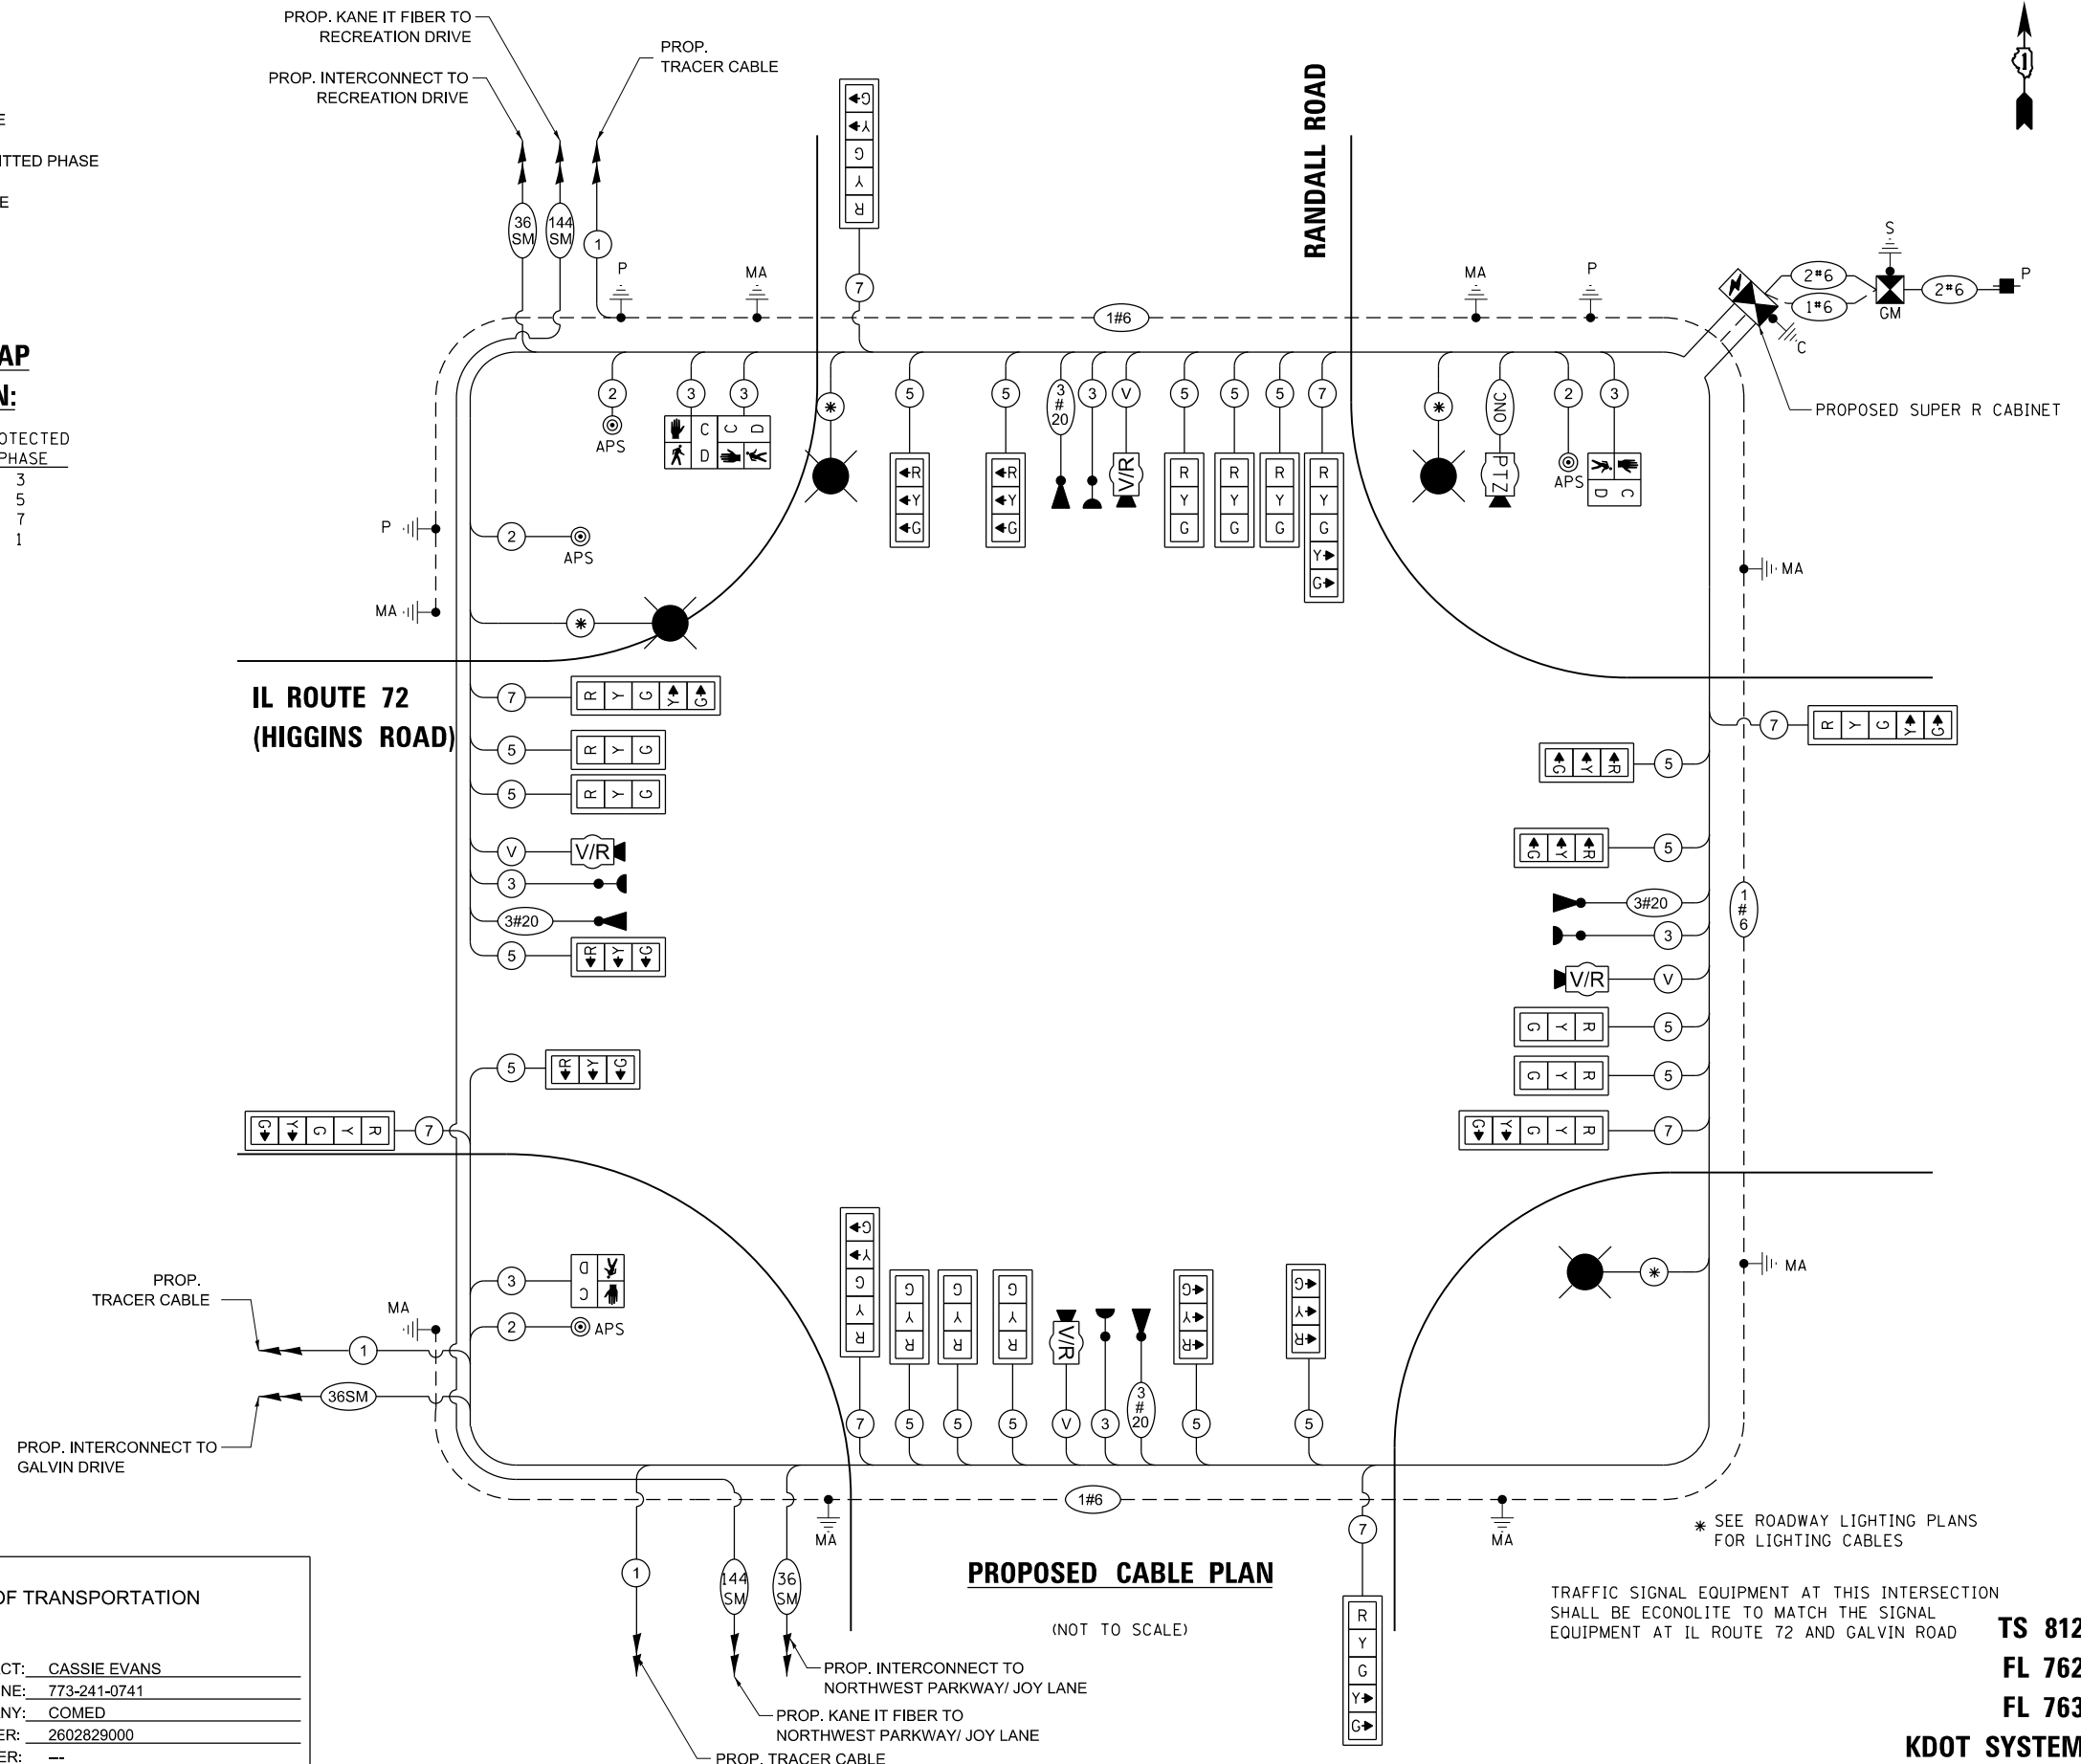

RANDALL ROAD AT IL ROUTE 72 CABLE PLAN, PHASE DESIGNATION DIAGRAM AND EMERGENCY VEHICLE PREEMPTION SEQUENCE							
SCALE:	NTS	SHEET	4	OF	4	SHEETS	STA. N/A TO STA. N/A

F.A.P. RTE.	SECTION	COUNTY	TOTAL SHEETS	SHEET NO.
0336	19-00514-00-WR	KANE	304	182
		CONTRACT NO. 61L28		
		ILLINOIS FED. AID PROJECT		

  ALL DIMENSIONS ARE IN INCHES UNLESS NOTED OTHERWISE



NOTE: FOR ADDITIONAL DESIGN AND INSTALLATION INFORMATION
PLEASE SEE DISTRICT ONE MAST ARM MOUNTED STREET NAME
SIGNS DETAIL.


ITEM	UNIT	TOTAL QUANTITY
SIGN PANEL - TYPE 1	SQ FT	18
SIGN PANEL - TYPE 2	SQ FT	25
UNDERGROUND CONDUIT, GALVANIZED STEEL, 2" DIA	FOOT	185
UNDERGROUND CONDUIT, GALVANIZED STEEL, 3" DIA	FOOT	96
UNDERGROUND CONDUIT, GALVANIZED STEEL, 4" DIA	FOOT	1087
DOUBLE HANDHOLE	EACH	4
ELECTRICCABLE IN CONDUIT, SIGNAL NO. 14 2C	FOOT	1118
ELECTRICCABLE IN CONDUIT, SIGNAL NO. 14 3C	FOOT	3795
ELECTRICCABLE IN CONDUIT, SIGNAL NO. 14 5C	FOOT	5241
ELECTRICCABLE IN CONDUIT, SIGNAL NO. 14 7C	FOOT	2450
ELECTRICCABLE IN CONDUIT, SERVICE, NO. 6 2C	FOOT	79
ELECTRICCABLE IN CONDUIT, EQUIPMENT GROUNDING CONDUCTOR, NO. 6 1C	FOOT	817
STEELMAST ARM ASSEMBLY AND POLE, 30 FT.	EACH	1
STEELMAST ARM ASSEMBLY AND POLE, 36 FT.	EACH	1
STEELMAST ARM ASSEMBLY AND POLE, 40 FT.	EACH	1
STEELMAST ARM ASSEMBLY AND POLE, 46 FT.	EACH	1
STEELMAST ARM ASSEMBLY AND POLE, 62 FT.	EACH	1
STEEL COMBINATION MAST ARM ASSEMBLY AND POLE 58 FT.	EACH	1
STEEL COMBINATION MAST ARM ASSEMBLY AND POLE 60 FT.	EACH	1
STEEL COMBINATION MAST ARM ASSEMBLY AND POLE 62 FT.	EACH	1
CONCRETEFOUNDATION, TYPE A	FOOT	4
CONCRETEFOUNDATION, TYPE C	FOOT	4
CONCRETEFOUNDATION, TYPE E 30 - INCH DIAMETER	FOOT	15.5
CONCRETEFOUNDATION, TYPE E 36 - INCH DIAMETER	FOOT	51.5
CONCRETEFOUNDATION, TYPE E 42 - INCH DIAMETER	FOOT	64
SIGNAL HEAD, LED, 1-FACE, 3-SECTION, MAST-ARM MOUNTED	EACH	18
SIGNAL HEAD, LED, 1-FACE, 5-SECTION, MAST-ARM MOUNTED	EACH	8
PEDESTRIANSIGNAL HEAD, LED, 1-FACE, BRACKET MOUNTED WITH COUNTDOWN TIMER	EACH	4
TRAFFICSIGNAL BACKPLATE, LOUVERED, FORMED PLASTIC	EACH	26
LIGHT DETECTOR	EACH	4
LIGHT DETECTOR AMPLIFIER	EACH	1
TEMPORARYTRAFFIC SIGNAL INSTALLATION	EACH	1
RELOCATEEXISTING FLASHING BEACON	EACH	2
REMOVEEXISTING TRAFFIC SIGNAL EQUIPMENT	EACH	1
REMOVEEXISTING HANDHOLE	EACH	10
REMOVEEXISTING DOUBLE HANDHOLE	EACH	2
REMOVEEXISTING CONCRETE FOUNDATION	EACH	9
EMERGENCYVEHICLE PRORITY SYSTEM LINE SENSOR CABLE, NO. 20 3C	FOOT	1280
OUTDOOR RATED NETWORK CABLE	FOOT	157
SERVICEINSTALLATION, GROUND MOUNTED, METERED	EACH	1
LAYERII (DATALINK SWITCH)	EACH	1
PEDESTRIANSIGNAL POST, 10 FT.	EACH	1
PEDESTRIANSIGNAL POST, 5 FT.	EACH	2
TEMPORARYFLASHING BEACON INSTALLATION	EACH	2
MAINTENANCE OF EXISTING FLASHING BEACON INSTALLATION	EACH	2
FULL-ACTUATED CONTROLLER AND TYPE SUPER R CABINET (SPECIAL)	EACH	1
UNINTERRUPTABLEPOWER SUPPLY (SPECIAL)	EACH	1
FIBER OPTIC INTERCONNECT 48 PORTS	EACH	1
ACCESSIBLEPEDESTRIAN SIGNALS	EACH	4
CONCRETEFOUNDATION, TYPE A 12-INCH DIAMETER	FOOT	12
LED SIGNAL FACE LENS COVER	EACH	26
VIDEO AND RADAR HYBRID DETECTON SYSTEM	EACH	1
INTERSECTIONVIDEO TRAFFIC MONITORING SYSTEM WITH PTZ CAMERA	EACH	1
RE-OPTIMIZE TRAFFIC SIGNAL SYSTEM LEVEL 2	EACH	1
TEMPORARYTRAFFIC SIGNAL TIMING	EACH	1
ETHERNET MANAGED SWITCH, TYPE 1	EACH	0
REMOVEEXISTING FLASHING BEACON INSTALLATION COMPLETE	EACH	2

- 100% COST TO KANE COUNTY

STATE OF ILLINOIS
DEPARTMENT OF TRANSPORTATION

**MAST ARM MOUNTED STREET NAMES SIGNS AND
SCHEDULE OF QUANTITIES
RANDALL ROAD AT IL ROUTE 72 (HIGGINS ROAD)**

F.A.P. RTE.	SECTION	COUNTY	TOTAL SHEETS	SHEET NO.
0336	19-00514-00-WR	KANE	304	183
CONTRACT NO. 61L28				
ILLINOIS		FED. AID PROJECT		

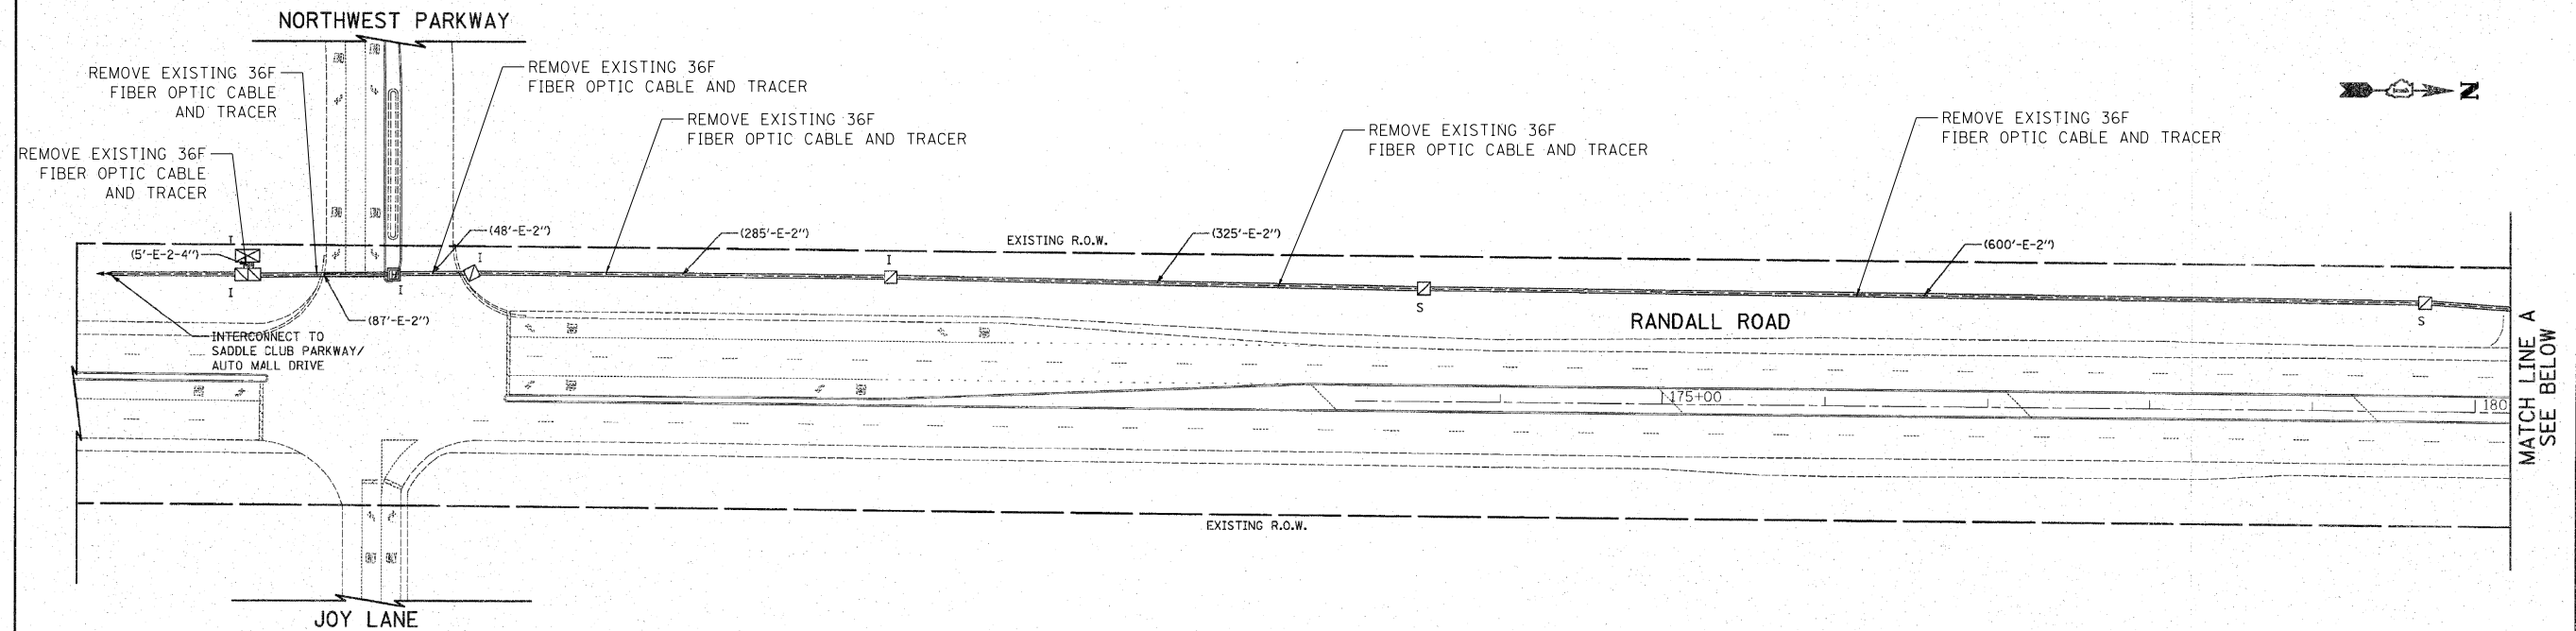

FILE NAME = ...\\P110208-08_Interconnect_Plan.dgn	USER NAME = bnd	DESIGNED BRU	REVISED -
		DRAWN OJT	REVISED -
		CHECKED JJE	REVISED -
		DATE 03/25/2011	REVISED -
PLOT SCALE = 50.0000' / in.			
PLOT DATE = 3/25/2011			

STATE OF ILLINOIS
DEPARTMENT OF TRANSPORTATION

RANDALL ROAD
INTERCONNECT PLAN
JOY LN/NORTHWEST PKWY TO BINNIE ROAD

SCALE: 1" = 50' SHEET NO. 1 OF 3 SHEETS STA. TO STA.

F.A.P. RTE.	SECTION	COUNTY	TOTAL SHEETS	SHEET NO.
341	62-N-1	KANE	148	72
CONTRACT NO. 60K09				
ILLINOIS FED. AID PROJECT				

MATCH LINE A
SEE BELOW

MODEL Dwg: BLA, Inc. - 19-00514-00-WR_SHT_01.dgn
FILE NAME: ...\\P110208-08_Interconnect_Plan.dgn



USER NAME = tnestor	DESIGNED - TN	REVISED -
	DRAWN - TN	REVISED -
PLOT SCALE = 100.0000' / in.	CHECKED - GJE	REVISED -
PLOT DATE = 8/21/2025	DATE - 02/15/2025	REVISED -

STATE OF ILLINOIS
DEPARTMENT OF TRANSPORTATION

RANDALL ROAD AT IL ROUTE 72 (HIGGINS ROAD)
PROPOSED INTERCONNECT PLANS


SCALE: NTS SHEET 1 OF 5 SHEETS STA. N/A TO STA. N/A

F.A.P. RTE.	SECTION	COUNTY	TOTAL SHEETS	SHEET NO.
0336	19-00514-00-WR	KANE	304	184
CONTRACT NO. 61L28				
ILLINOIS FED. AID PROJECT				

DOT SYSTEM



KANE I.T. HH 36"x60"x36" WITH TIER,
LABEL: "KANE INFORMATION TECHNOLOGY"
WITH 1-4" CONDUIT TO TRAFFIC SIGNAL HH.

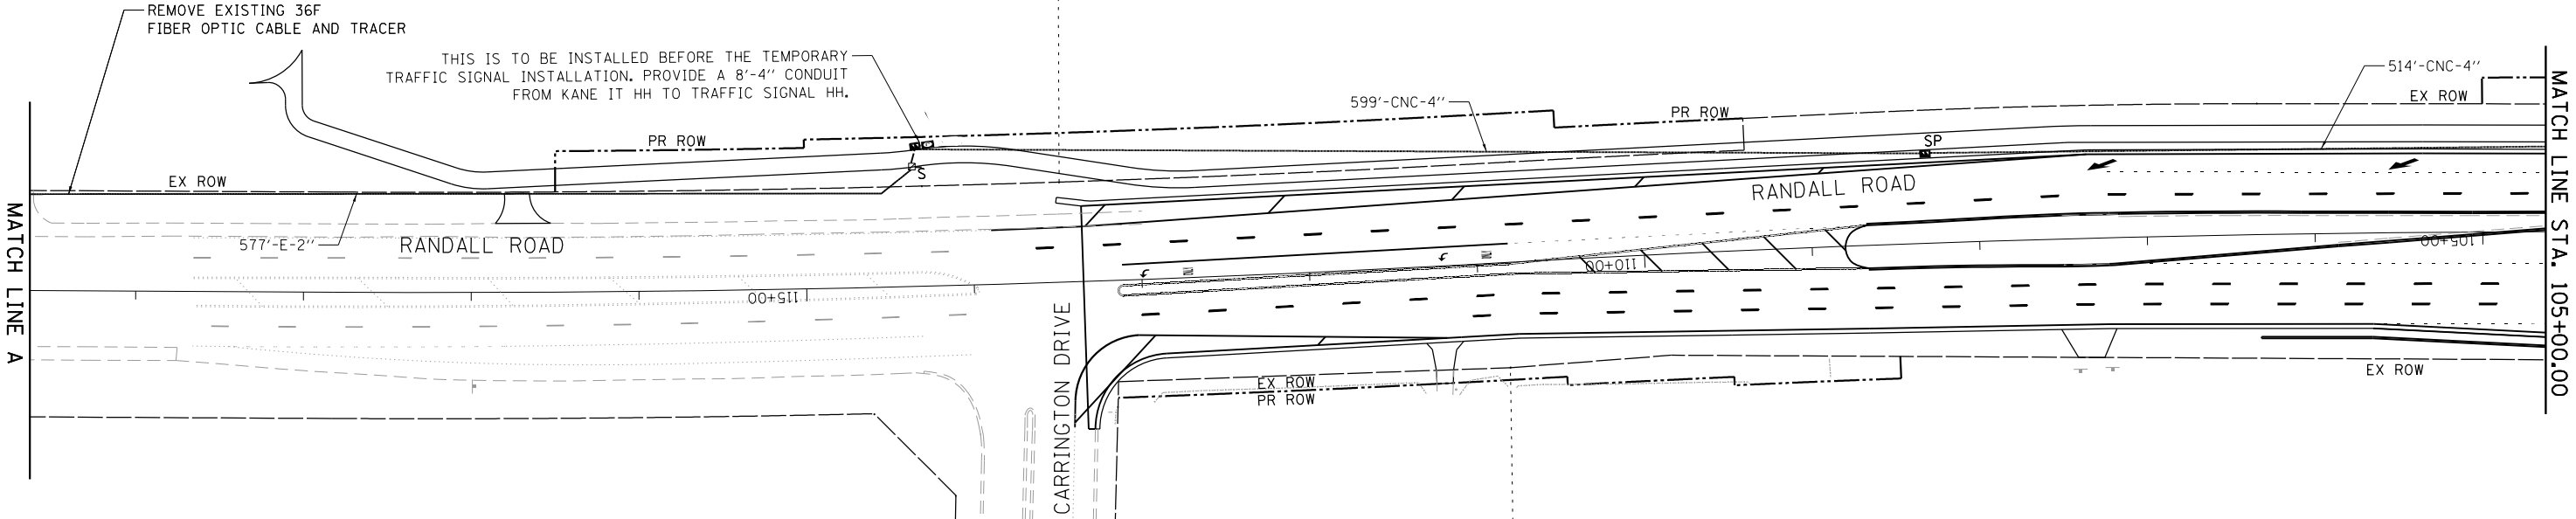

NOTE:
1. CONTRACTOR SHALL COORDINATE WITH KANE IT AND KANE IT FIBER CABLE CONTRACTOR
NTI AT LEBOKURT@KANECOUNTYIL.GOV AND ATNSCHROEDER@NTITECH.COM FOR THE 144SM
FIBER SPLICE AND TERMINATION. THIS THIS WORK SHALL BE INCLUDED IN THE CONTRACT
UNIT PRICE FOR "TEMPORARY INTERCONNECT."
2. ALL COILABLE NONMETALLIC CONDUIT AND GALVANIZED STEEL CONDUITS SHALL BE
INSTALLED AT THE MINIMUM OF 42 INCHES FROM THE GRADE.

KDOT SYSTEM

MODEL: Default
FILE NAME: W:\94\988\Randall at Higgins Phase II Engineering\CADD_Sheets\016_Traffic Signals\19-00514-00-WR_SHT_02_Prop Interconnect Plan 02.dgn



BLA, Inc.

USER NAME = tnestor	DESIGNED - TN	REVISED -
	DRAWN - TN	REVISED -
PLOT SCALE = 100.0000 ' / in.	CHECKED - GJE	REVISED -
PLOT DATE = 8/21/2025	DATE - 02/15/2025	REVISED -

STATE OF ILLINOIS
DEPARTMENT OF TRANSPORTATION

RANDALL ROAD AT IL ROUTE 72 (HIGGINS ROAD)
PROPOSED INTERCONNECT PLANS

SCALE: 1"=50' SHEET 2 OF 4 SHEETS STA. 119+63.18 TO STA. 105+00.00



F.A.P. RTE.	SECTION	COUNTY	TOTAL SHEETS	SHEET NO.
0336	19-00514-00-WR	KANE	304	185
CONTRACT NO. 61L28				
ILLINOIS FED. AID PROJECT				



KANE I.T. HH 36"x60"x36" WITH TIER,
LABEL: "KANE INFORMATION TECHNOLOGY"
WITH 1-4" CONDUIT TO TRAFFIC SIGNAL HH.

MATCH LINE STA. 198+00.00
IL ROUTE 72 (HIGGINS ROAD)

NOTE:
1. CONTRACTOR SHALL COORDINATE WITH KANE IT AND KANE IT FIBER CABLE CONTRACTOR
NTI AT LEBOKURT@KANECOUNTYIL.GOV AND ATNSCHROEDER@NTITECH.COM FOR THE 144SM
FIBER SPLICE AND TERMINATION. THIS THIS WORK SHALL BE INCLUDED IN THE CONTRACT
UNIT PRICE FOR "TEMPORARY INTERCONNECT."
2. ALL COILABLE NONMETALLIC CONDUIT AND GALVANIZED STEEL CONDUITS SHALL BE
INSTALLED AT THE MINIMUM OF 42 INCHES FROM THE GRADE.

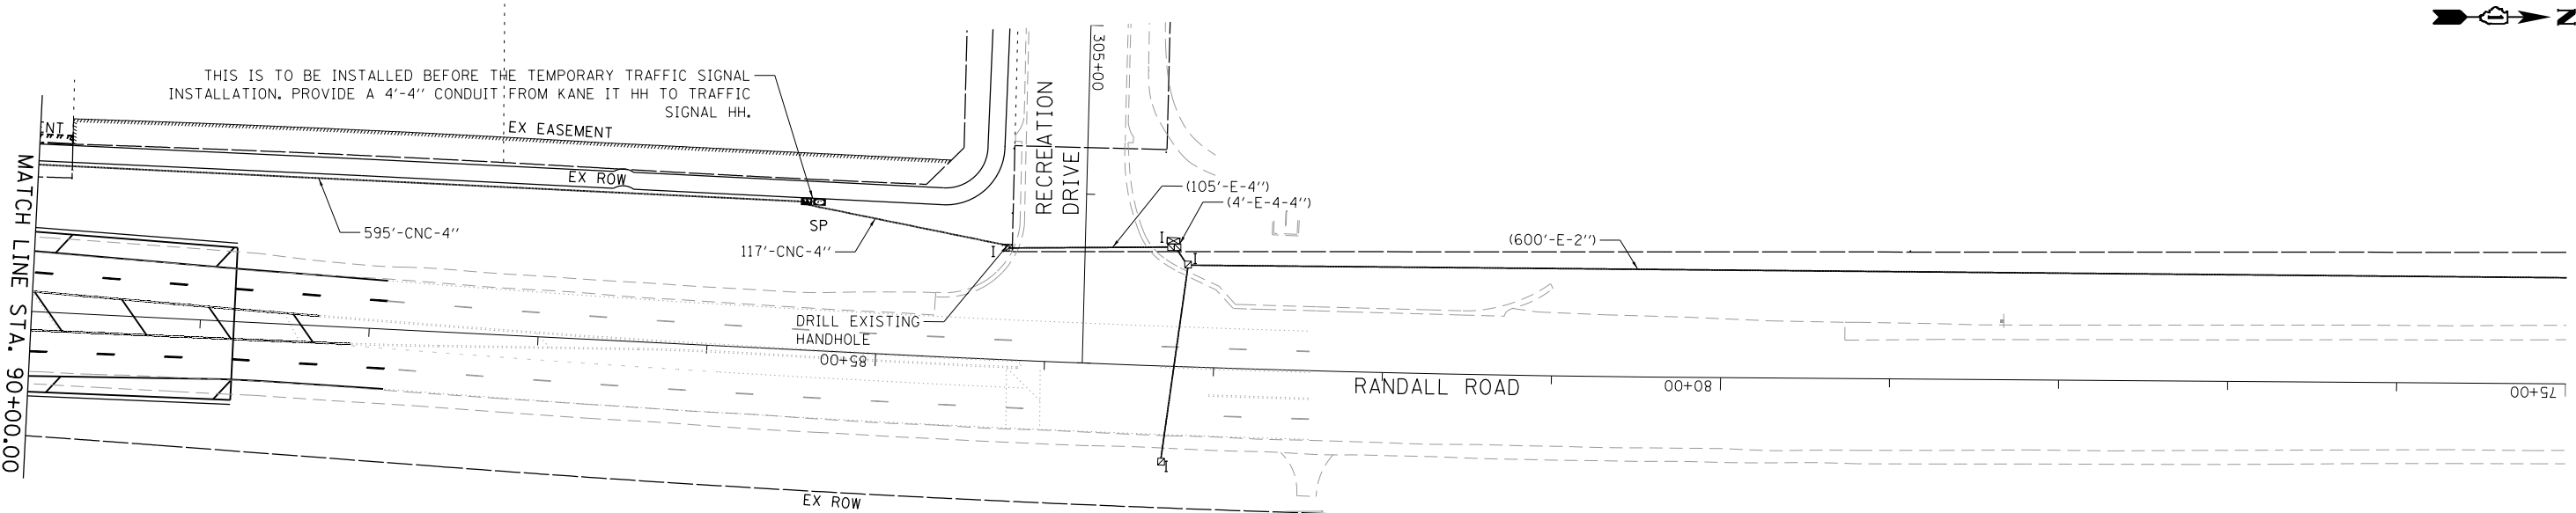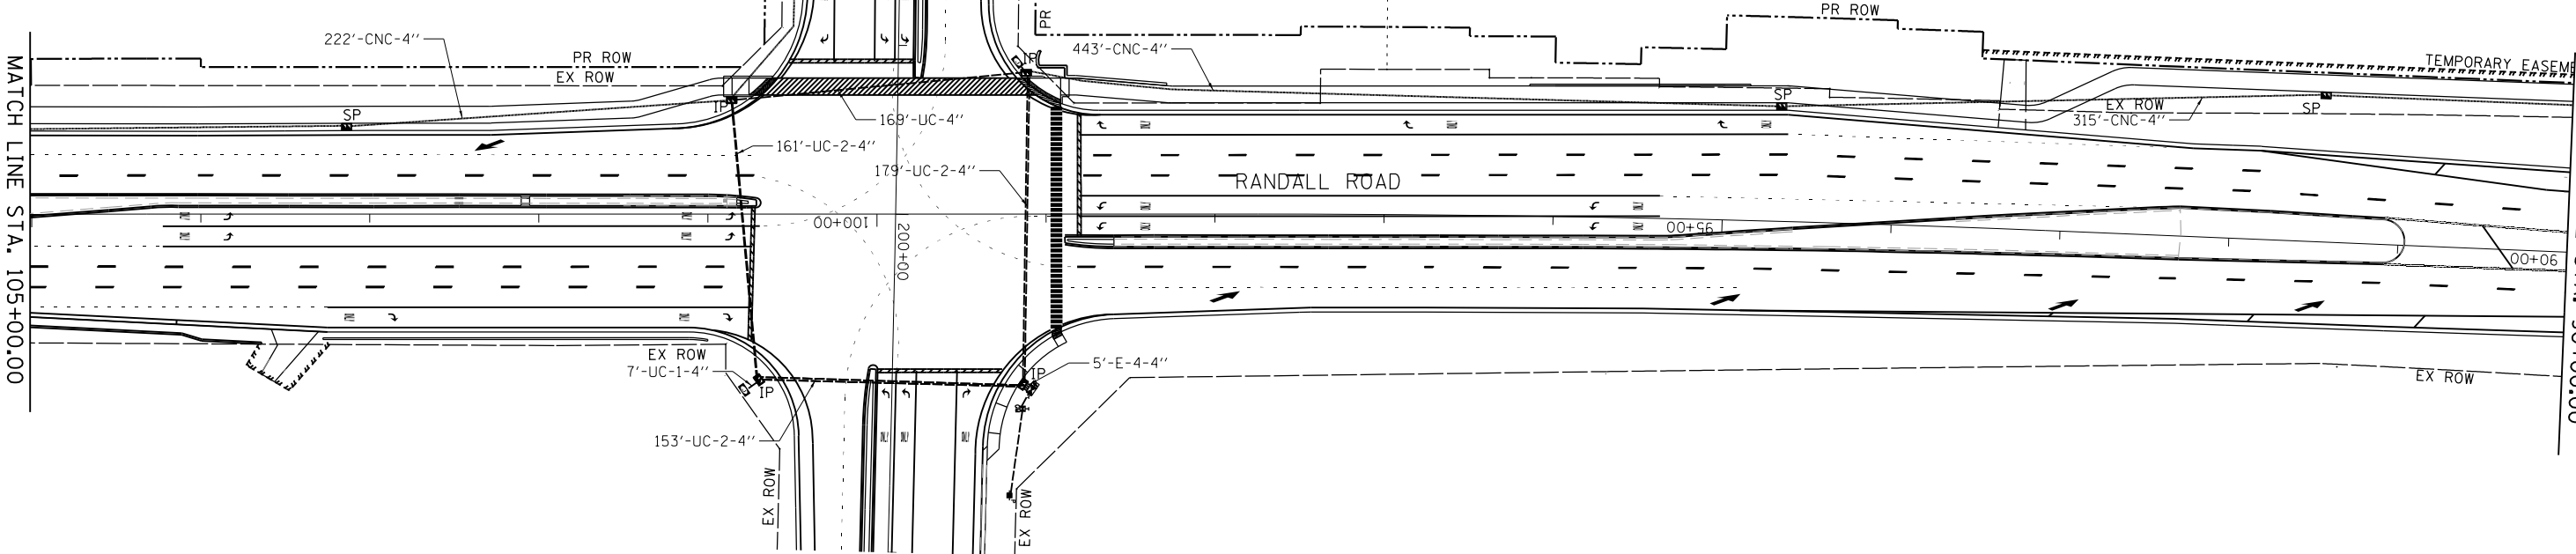

KDOT SYSTEM



BLA, Inc.

USER NAME = tnestor	DESIGNED - TN	REVISED -
	DRAWN - TN	REVISED -
PLOT SCALE = 100.0000' / in.	CHECKED - GJE	REVISED -
PLOT DATE = 8/21/2025	DATE - 02/15/2025	REVISED -

STATE OF ILLINOIS
DEPARTMENT OF TRANSPORTATION

RANDALL ROAD AT IL ROUTE 72 (HIGGINS ROAD)
PROPOSED INTERCONNECT PLANS

SCALE: 1"=50' SHEET 3 OF 4 SHEETS STA. 105+00.00 TO STA. 75+00.00

F.A.P. RTE.	SECTION	COUNTY	TOTAL SHEETS	SHEET NO.
0336	19-00514-00-WR	KANE	304	186
CONTRACT NO. 61L28				
ILLINOIS FED. AID PROJECT				

MODEL: Default
FILE NAME: W:\894988 Randall at Higgins Phase II Engineering\CADD Sheets\016 Traffic Signals\19-00514-00-WR_SHT_PR_Interconnect Plan 03.dgn

MODEL: D:\bls\19-00514-00-WR_SHT_05.dgn
FILE NAME: 19-00514-00-WR_SHT_05.dgn
PROJECT: RANDALL ROAD AT IL ROUTE 72 (HIGGINS ROAD) - Phase II Engineering (CADD, Sheets 018, Traffic Signals) 19-00514-00-WR_SHT_05.dgn



USER NAME : tnestor	DESIGNED - TN	REVISED -
	DRAWN - TN	REVISED -
PLOT SCALE = 100.0000' / in.	CHECKED - GJE	REVISED -
PLOT DATE = 8/21/2025	DATE - 02/15/2025	REVISED -


STATE OF ILLINOIS
DEPARTMENT OF TRANSPORTATION

RANDALL ROAD AT IL ROUTE 72 (HIGGINS ROAD) PROPOSED INTERCONNECT PLANS			
SCALE: 1"=50'	SHEET 4	OF 4 SHEETS	STA. 175+50.00 TO STA. 198+00.00

F.A.P. RTE.	SECTION	COUNTY	TOTAL SHEETS	SHEET NO.
0336	19-00514-00-WR	KANE	304	187
CONTRACT NO. 61L28				
ILLINOIS FED. AID PROJECT				

KDOT SYSTEM

MATCH LINE STA. 183+00.00

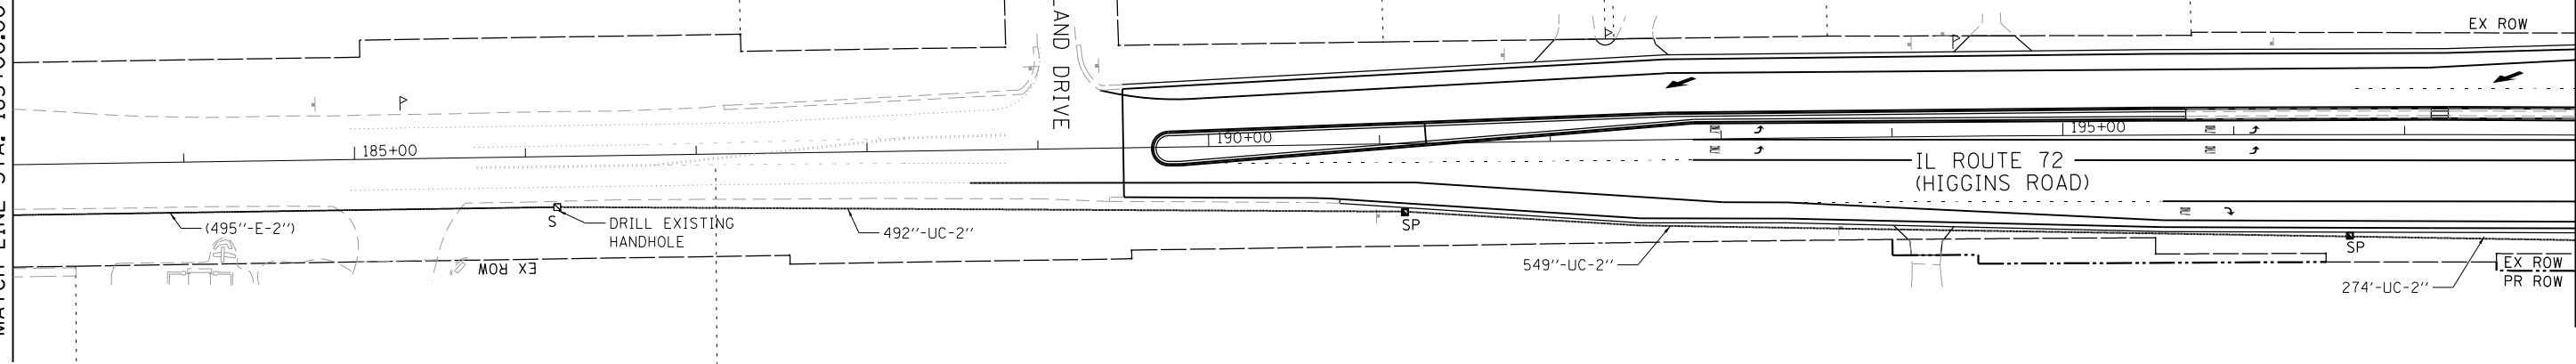

MATCH LINE STA. 198+00.00

IL ROUTE 72
(HIGGINS ROAD)


GALVIN DRIVE

HIGHLAND DRIVE

MATCH LINE STA. 183+00.00



MODEL: Default
FILE NAME: V:\894-088 Randall at Higgins Phase II Engineering\CADD Sheets\016 Traffic Signals\19-00514-00-WR_SHT_PR_Interconnect_Schematic.dgn

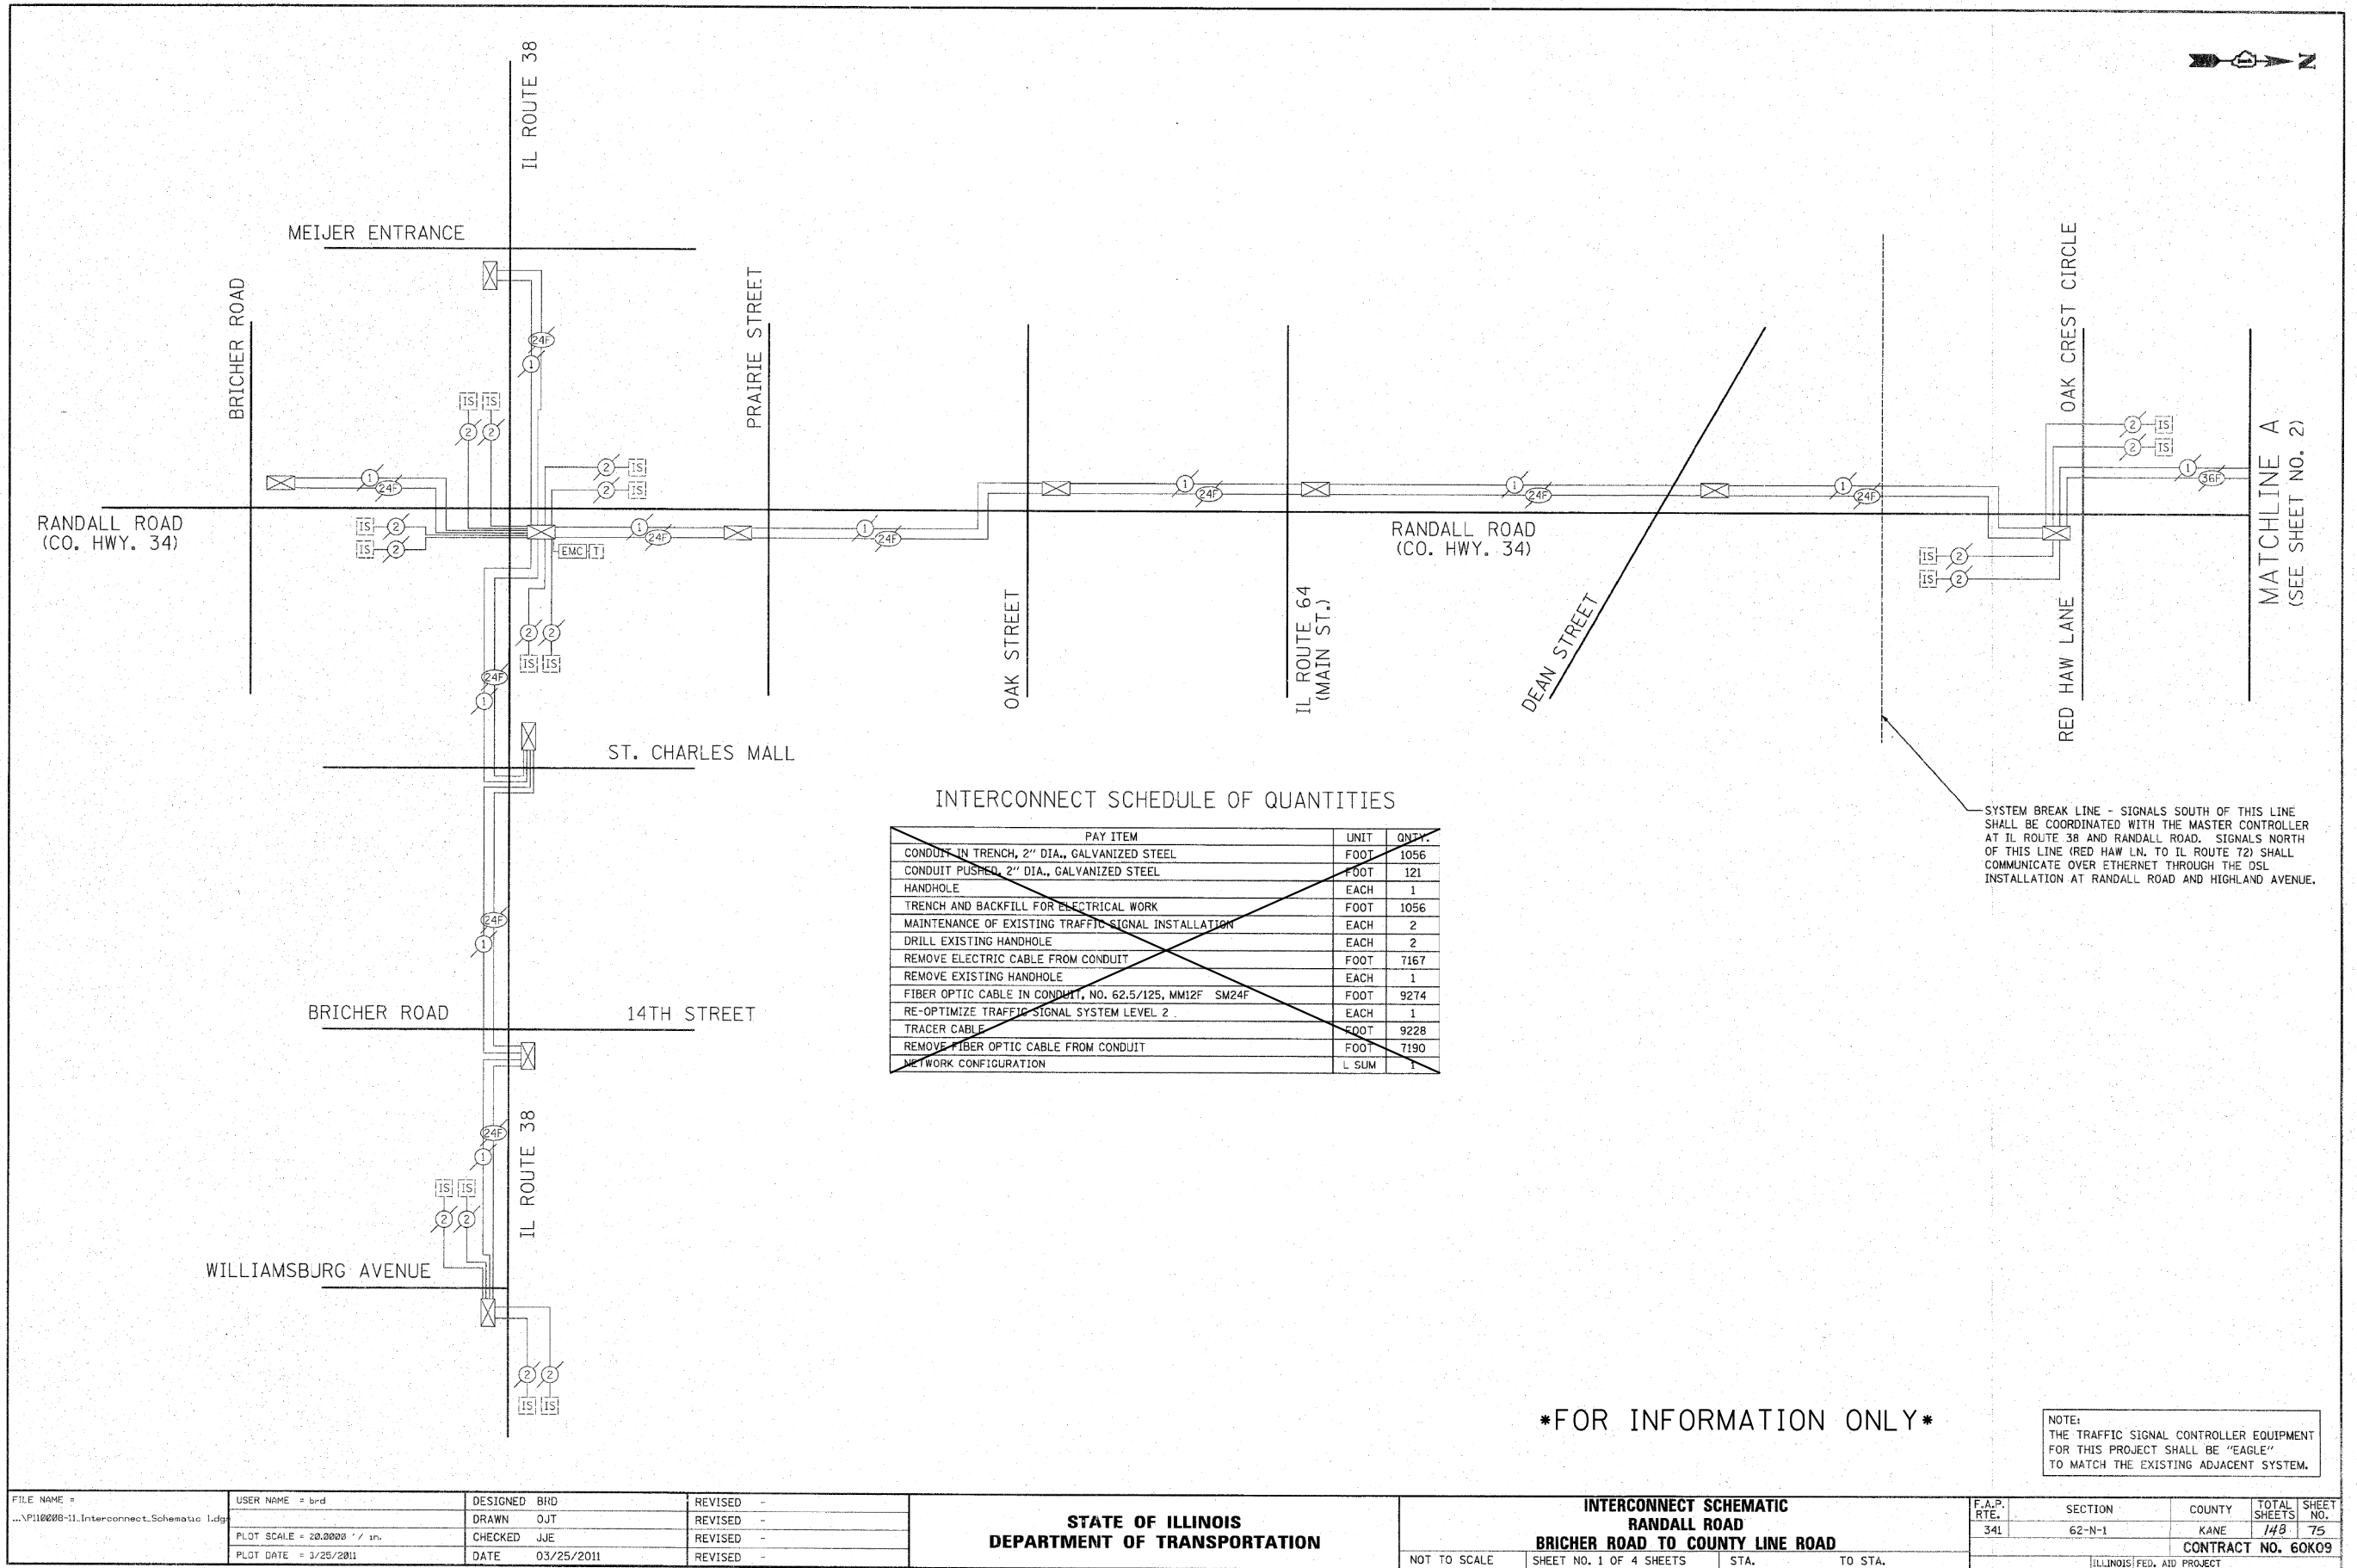

BLA, Inc.

USER NAME = tnestor	DESIGNED - TN	REVISED -
PLOT SCALE = 100.0000' / in.	DRAWN - TN	REVISED -
PLOT DATE = 8/21/2025	CHECKED - GJE	REVISED -
	DATE - 02/15/2025	REVISED -

STATE OF ILLINOIS
DEPARTMENT OF TRANSPORTATION

RANDALL ROAD AT IL ROUTE 72 (HIGGINS ROAD)
PROPOSED INTERCONNECT SCHEMATIC AND SCHEDULE OF QUANTITIES

SCALE: NTS

SHEET 1 OF 4 SHEETS

STA. N/A TO STA. N/A

F.A.P. RTE. 0336	SECTION 19-00514-00-WR	COUNTY KANE	TOTAL SHEETS 304	SHEET NO. 188
CONTRACT NO. 61L28				
ILLINOIS FED. AID PROJECT				

KDOT SYSTEM

MODEL: Default
FILE NAME: W:\894-088 Randall at Higgins Phase II Engineering\CADD Sheets\016 Traffic Signals\19-00514-00-WR_SHT_FR Interconnect_Schematic.dgn



BLA, Inc.


USER NAME = tnestor	DESIGNED - TN	REVISED -
PLOT SCALE = 100.0000' / in.	DRAWN - TN	REVISED -
PLOT DATE = 8/21/2025	CHECKED - GJE	REVISED -
	DATE - 02/15/2025	REVISED -

STATE OF ILLINOIS
DEPARTMENT OF TRANSPORTATION

RANDALL ROAD AT IL ROUTE 72 (HIGGINS ROAD)
PROPOSED INTERCONNECT SCHEMATIC AND SCHEDULE OF QUANTITIES

SCALE: NTS SHEET 2 OF 4 SHEETS STA. N/A TO STA. N/A

F.A.P. RTE.	SECTION	COUNTY	TOTAL SHEETS	SHEET NO.
0336	19-00514-00-WR	KANE	304	189
CONTRACT NO. 61L28				
ILLINOIS FED. AID PROJECT				

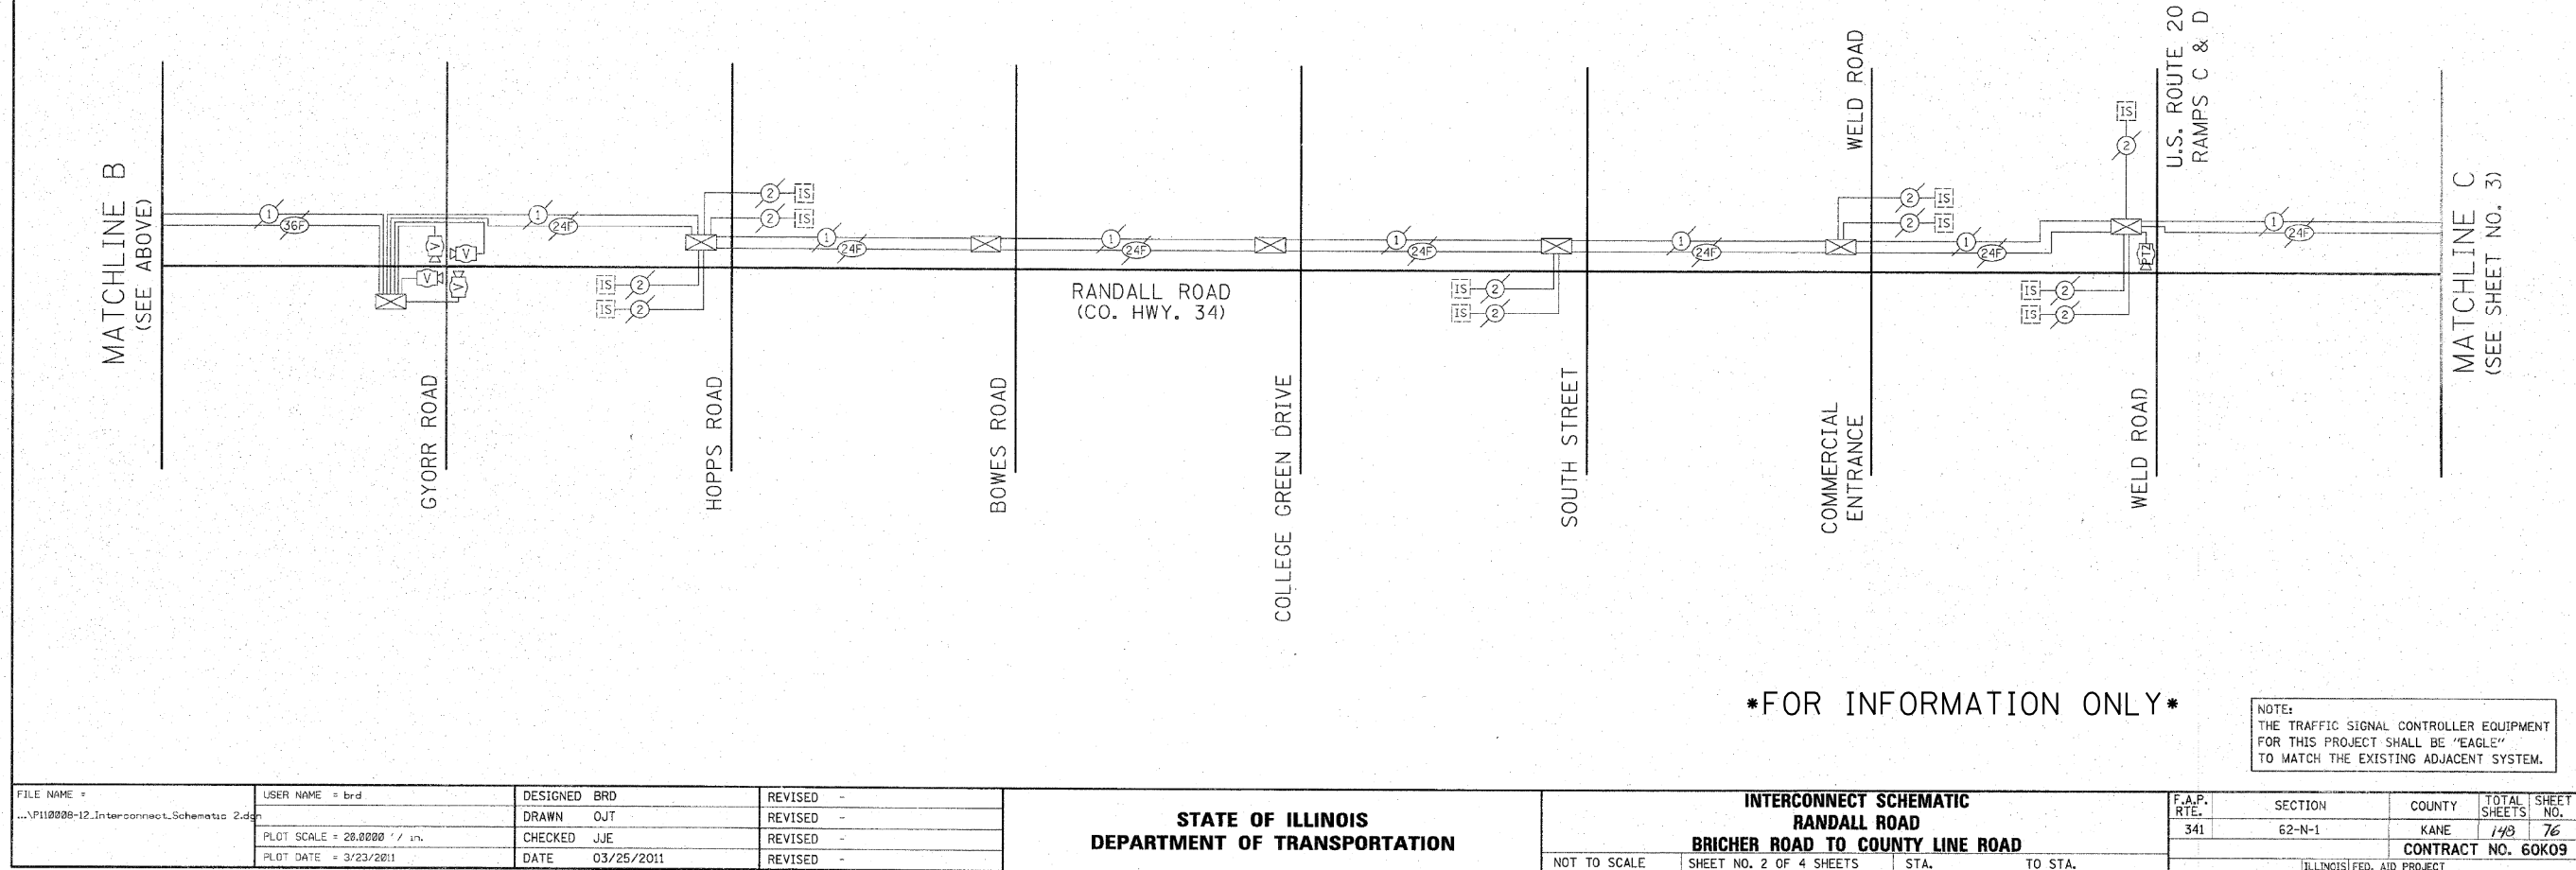

MATCHLINE B
(SEE ABOVE)

MATCHLINE A
(SEE SHEET NO. 1)



MATCHLINE C
(SEE SHEET NO. 3)

MATCHLINE B
(SEE BELOW)





 KANE I.T. HH 36"X60"X36" WITH TIER,
LABEL: "KANE INFORMATION TECHNOLOGY"
WITH 1-4" CONDUIT TO TRAFFIC SIGNAL HH.

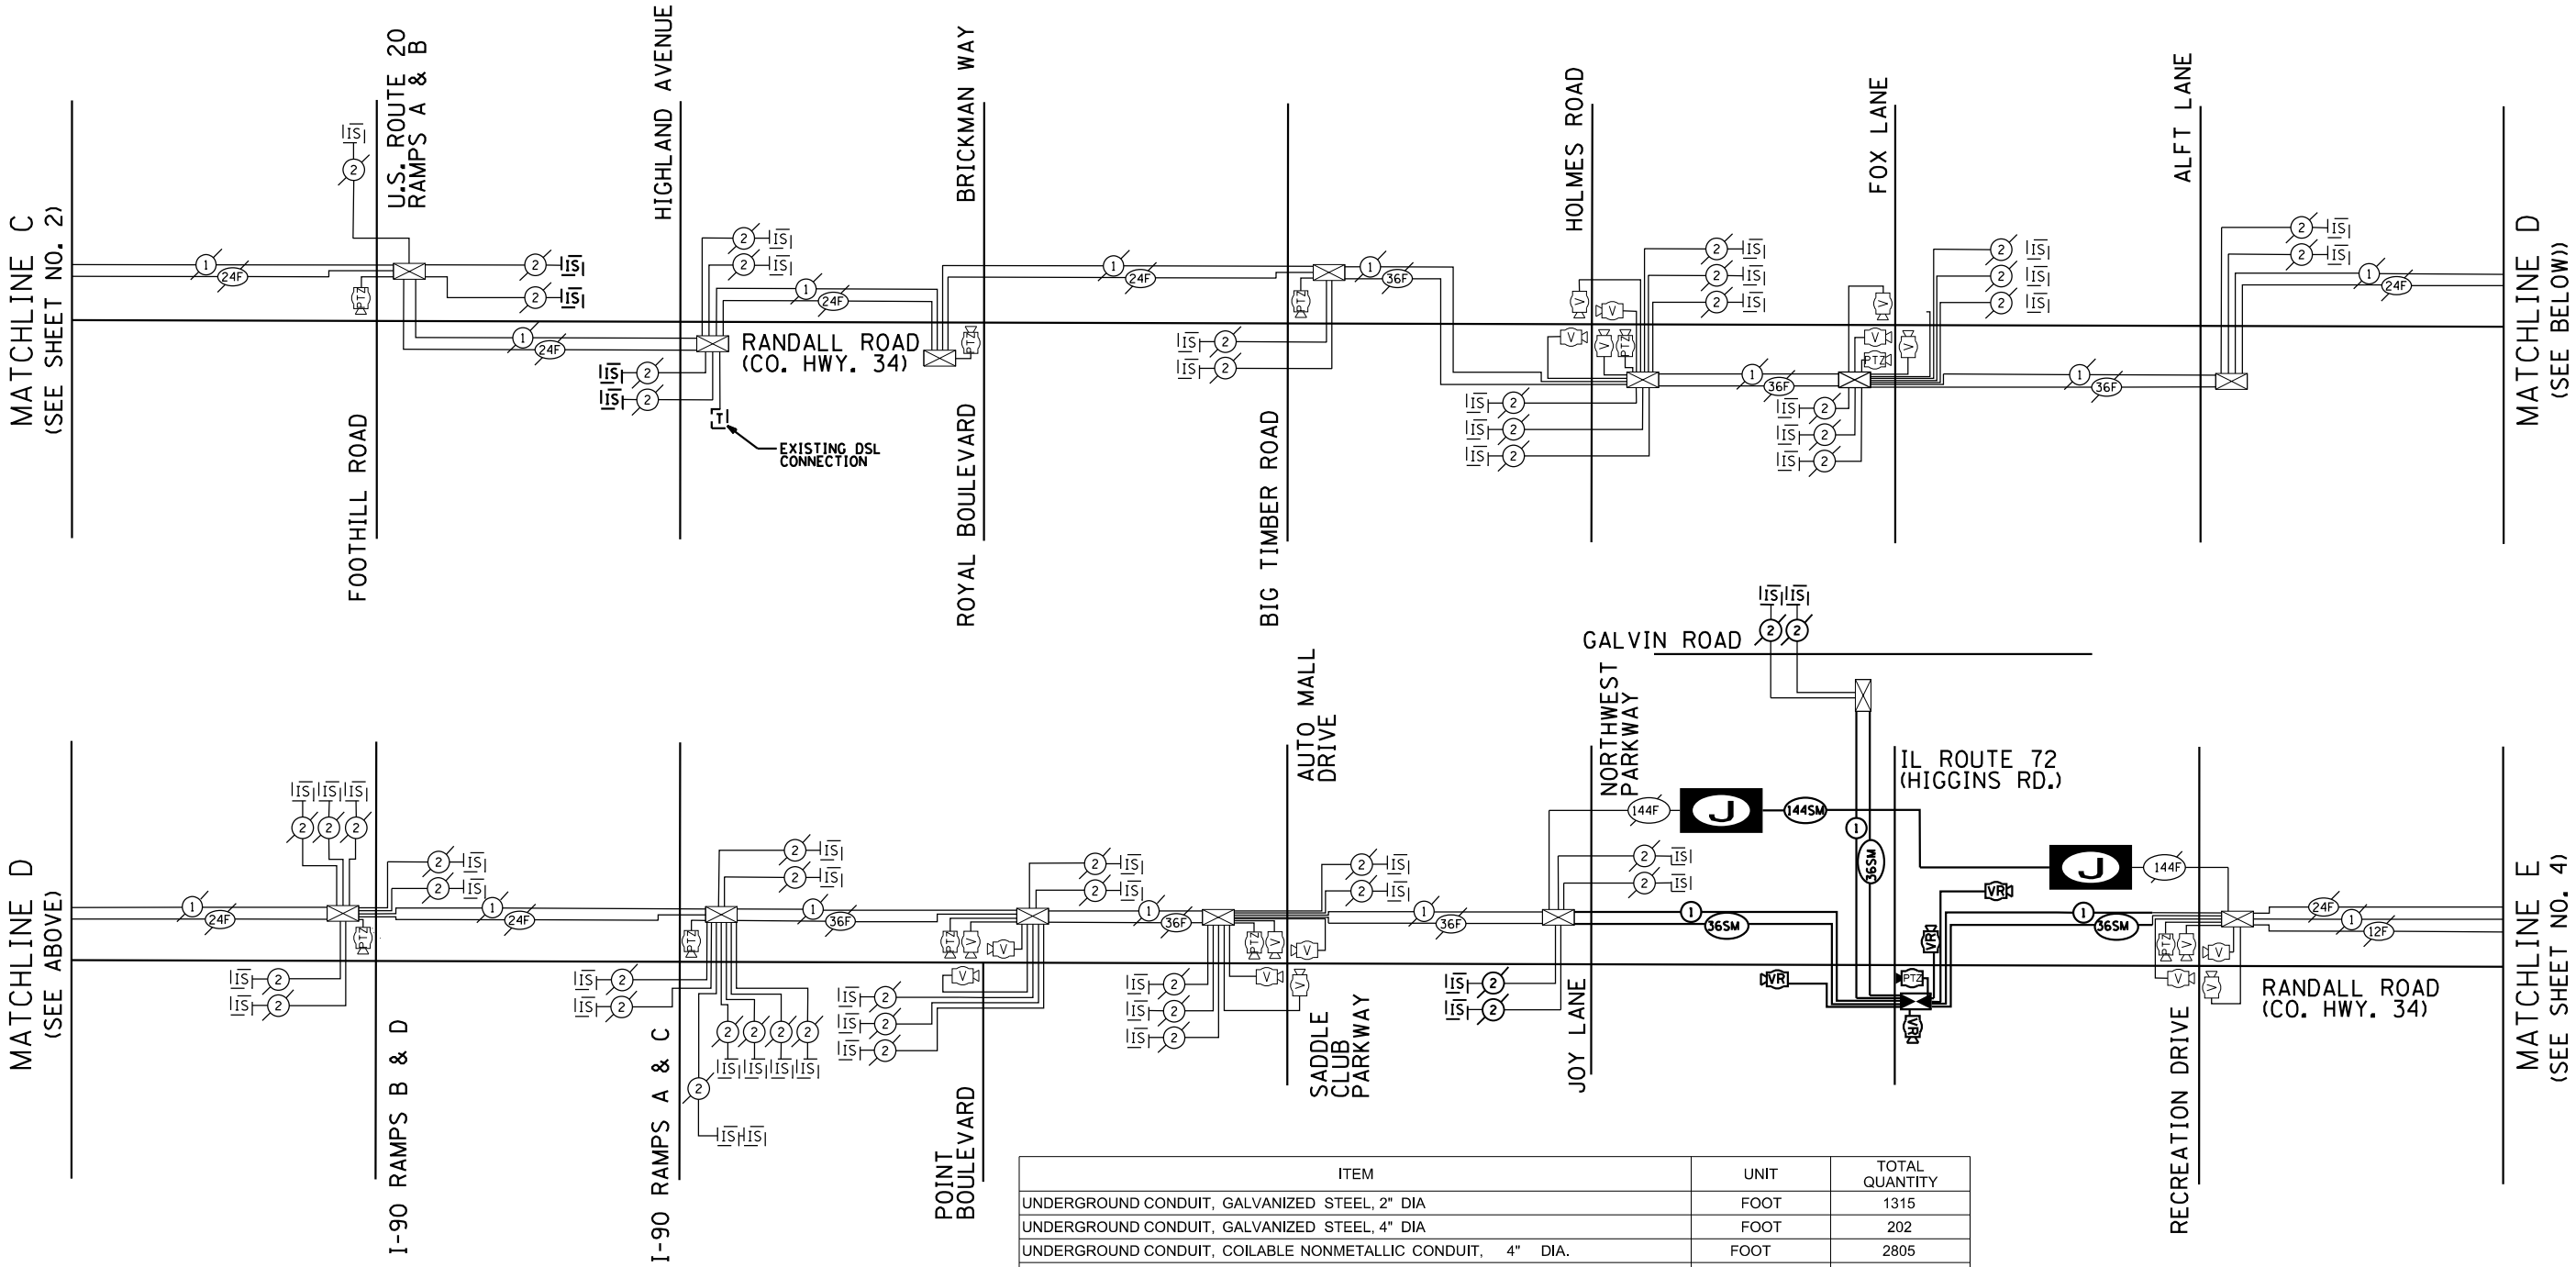

ITEM	UNIT	TOTAL QUANTITY
UNDERGROUND CONDUIT, GALVANIZED STEEL, 2" DIA	FOOT	1315
UNDERGROUND CONDUIT, GALVANIZED STEEL, 4" DIA	FOOT	202
UNDERGROUND CONDUIT, COILABLE NONMETALLIC CONDUIT, 4" DIA.	FOOT	2805
DOUBLE HANDHOLE	EACH	6
HANDHOLE, COMPOSITE CONCRETE	EACH	5
MAINTENANCE OF EXISTING TRAFFIC SIGNAL INSTALLION	EACH	3
ELECTRICCABLE IN CONDUIT, TRACER, NO. 14 1C	FOOT	2807
DRILL EXISTING HANDHOLE	EACH	2
REMOVEEELECTRIC CABLE FROM CONDUIT	FOOT	13889
REMOVEEXISTING HANDHOLE	EACH	10
NETWORK CONFIGURATION	L SUM	1
TERMINATE FIBER IN CABINET	EACH	4
SPLICEFIBER IN CABINET	EACH	4
FIBEROPTIC CABLE 36 FIBERS, SINGLE MODE	FOOT	8110
FIBEROPTIC CABLE 144 FIBERS, SINGLE MODE	FOOT	3123
TEMPORARY INTERCONNECT	L SUM	1
ROD AND CLEAN EXISTING CONDUIT	EACH	1927

NOTE:

1. THE PAY ITEM OF "MAINTENANCE OF EXISTING TRAFFIC SIGNAL INSTALLION" HAS BEEN INCLUDED AT THE INTERSECTIONS OF RANDALL ROAD AT RECREATION DRIVE, RANDALL ROAD AT JOY LANE AND IL-72 AT GALVIN DRIVE.
2. PROPOSED KANE IT 144SM FIBER CABLE TO BE INSTALLED IN NEW INTERCONNECT CONDUIT FROM STA 85+50 TO STA 144+50. THIS FIBER SHALL BYPASS THE INTERSECTION OF RANDALL ROAD AT IL ROUTE 72. SPLICES TO EXISTING KANE IT 144F FIBER TO BE COMPLETE BY KANE IT CONTRACTOR. CONTRACTOR SHALL COORDINATE WITH KANE IT AND KANE IT FIBER CABLE CONTRACTOR NTI AT LEBOKURT@KANECOUNTYIL.GOV AND ATNSCHROEDER@NTITECH.COM FOR THE 144SM FIBER SPLICE AND TERMINATION. THIS THIS WORK SHALL BE INCLUDED IN THE CONTRACT UNIT PRICE FOR "TEMPORARY INTERCONNECT."



BLA, Inc.

USER NAME = tnestor	DESIGNED - TN	REVISED -
	DRAWN - TN	REVISED -
PLOT SCALE = 100.0000' / in.	CHECKED - GJE	REVISED -
PLOT DATE = 8/21/2025	DATE - 02/15/2025	REVISED -

STATE OF ILLINOIS
DEPARTMENT OF TRANSPORTATION

RANDALL ROAD AT IL ROUTE 72 (HIGGINS ROAD)
PROPOSED INTERCONNECT SCHEMATIC AND SCHEDULE OF QUANTITIES


SCALE: NTS SHEET 3 OF 4 SHEETS STA. N/A TO STA. N/A

F.A.P. RTE.	SECTION	COUNTY	TOTAL SHEETS	SHEET NO.
0336	19-00514-00-WR	KANE	304	190
CONTRACT NO. 61L28				
ILLINOIS FED. AID PROJECT				

KDOT SYSTEM

MODEL: Default
FILE NAME: W:\894-088 Randall at Higgins Phase II Engineering\CADD Sheets\016 Traffic Signals\19-00514-00-WR_SHT_FR Interconnect_Schematic.dgn

MATCHLINE E
(SEE SHEET NO. 3)

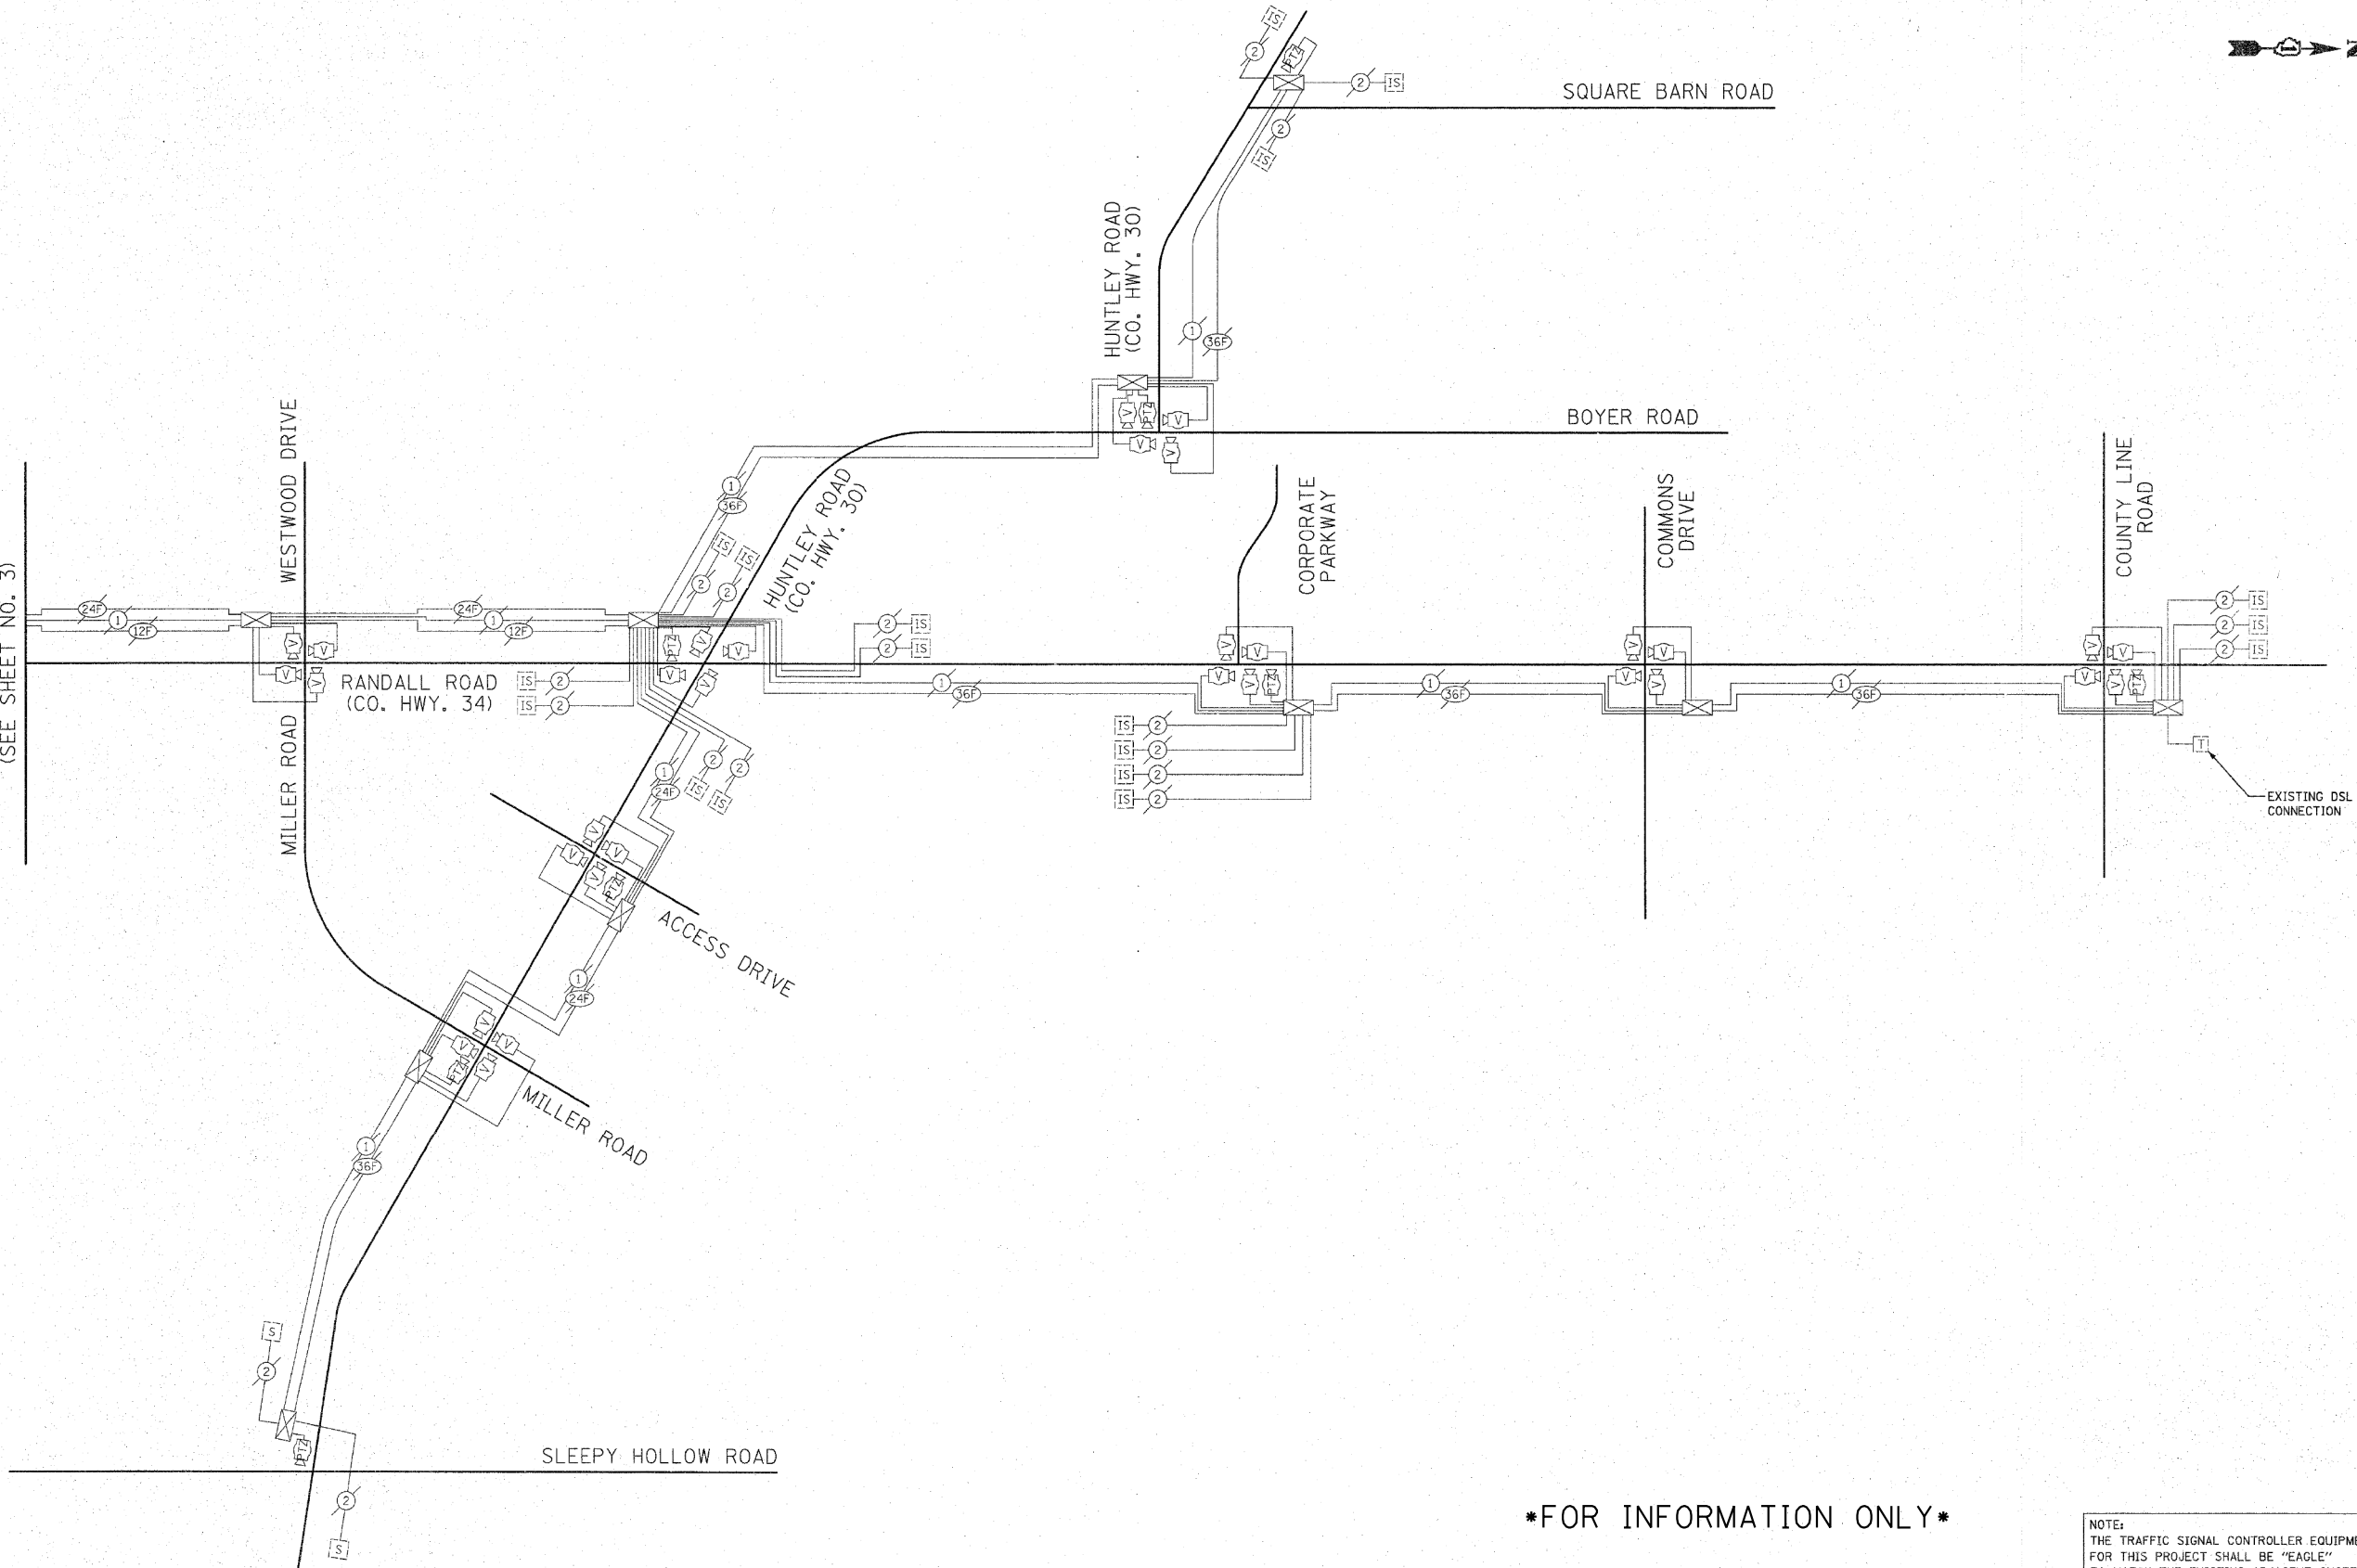

FOR INFORMATION ONLY

NOTE:
THE TRAFFIC SIGNAL CONTROLLER EQUIPMENT
FOR THIS PROJECT SHALL BE "EAGLE"
TO MATCH THE EXISTING ADJACENT SYSTEM.

FILE NAME =	USER NAME = brd	DESIGNED BRD	REVISED -	STATE OF ILLINOIS DEPARTMENT OF TRANSPORTATION	INTERCONNECT SCHEMATIC RANDALL ROAD BRICHER ROAD TO COUNTY LINE ROAD	NOT TO SCALE	SHEET NO. 4 OF 4 SHEETS	STA.	TO STA.	F.A.P. RTE. 341	SECTION 62-N-1	COUNTY KANE	TOTAL SHEETS 148	SHEET NO. 78	CONTRACT NO. 60K09	ILLINOIS FED. AID PROJECT
...VP110008-14_Interconnect_Schematic_4.dgn	PLOT SCALE = 20.0000' / 1in.	DRAWN OJT	REVISED -													
	PLOT DATE = 3/23/2011	CHECKED JJE	REVISED -													
		DATE 03/25/2011	REVISED -													



BLA, Inc.

USER NAME = tnestor	DESIGNED - TN	REVISED -
	DRAWN - TN	REVISED -
PLOT SCALE = 100.0000' / 1in.	CHECKED - GJE	REVISED -
PLOT DATE = 8/21/2025	DATE - 02/15/2025	REVISED -

STATE OF ILLINOIS
DEPARTMENT OF TRANSPORTATION


RANDALL ROAD AT IL ROUTE 72 (HIGGINS ROAD)
PROPOSED INTERCONNECT SCHEMATIC AND SCHEDULE OF QUANTITIES

SCALE: NTS SHEET 4 OF 4 SHEETS STA. N/A TO STA. N/A

F.A.P. RTE. 0336	SECTION 19-00514-00-WR	COUNTY KANE	TOTAL SHEETS 304	SHEET NO. 191
CONTRACT NO. 61L28				
ILLINOIS FED. AID PROJECT				

KDOT SYSTEM

MODEL: Default
FILE NAME: V:\894-088 Randall at Higgins Phase II Engineering\CADD Sheets\016 Traffic Signals\19-00514-00-WR_SHT_FR_Interconnect_Schematic.dgn

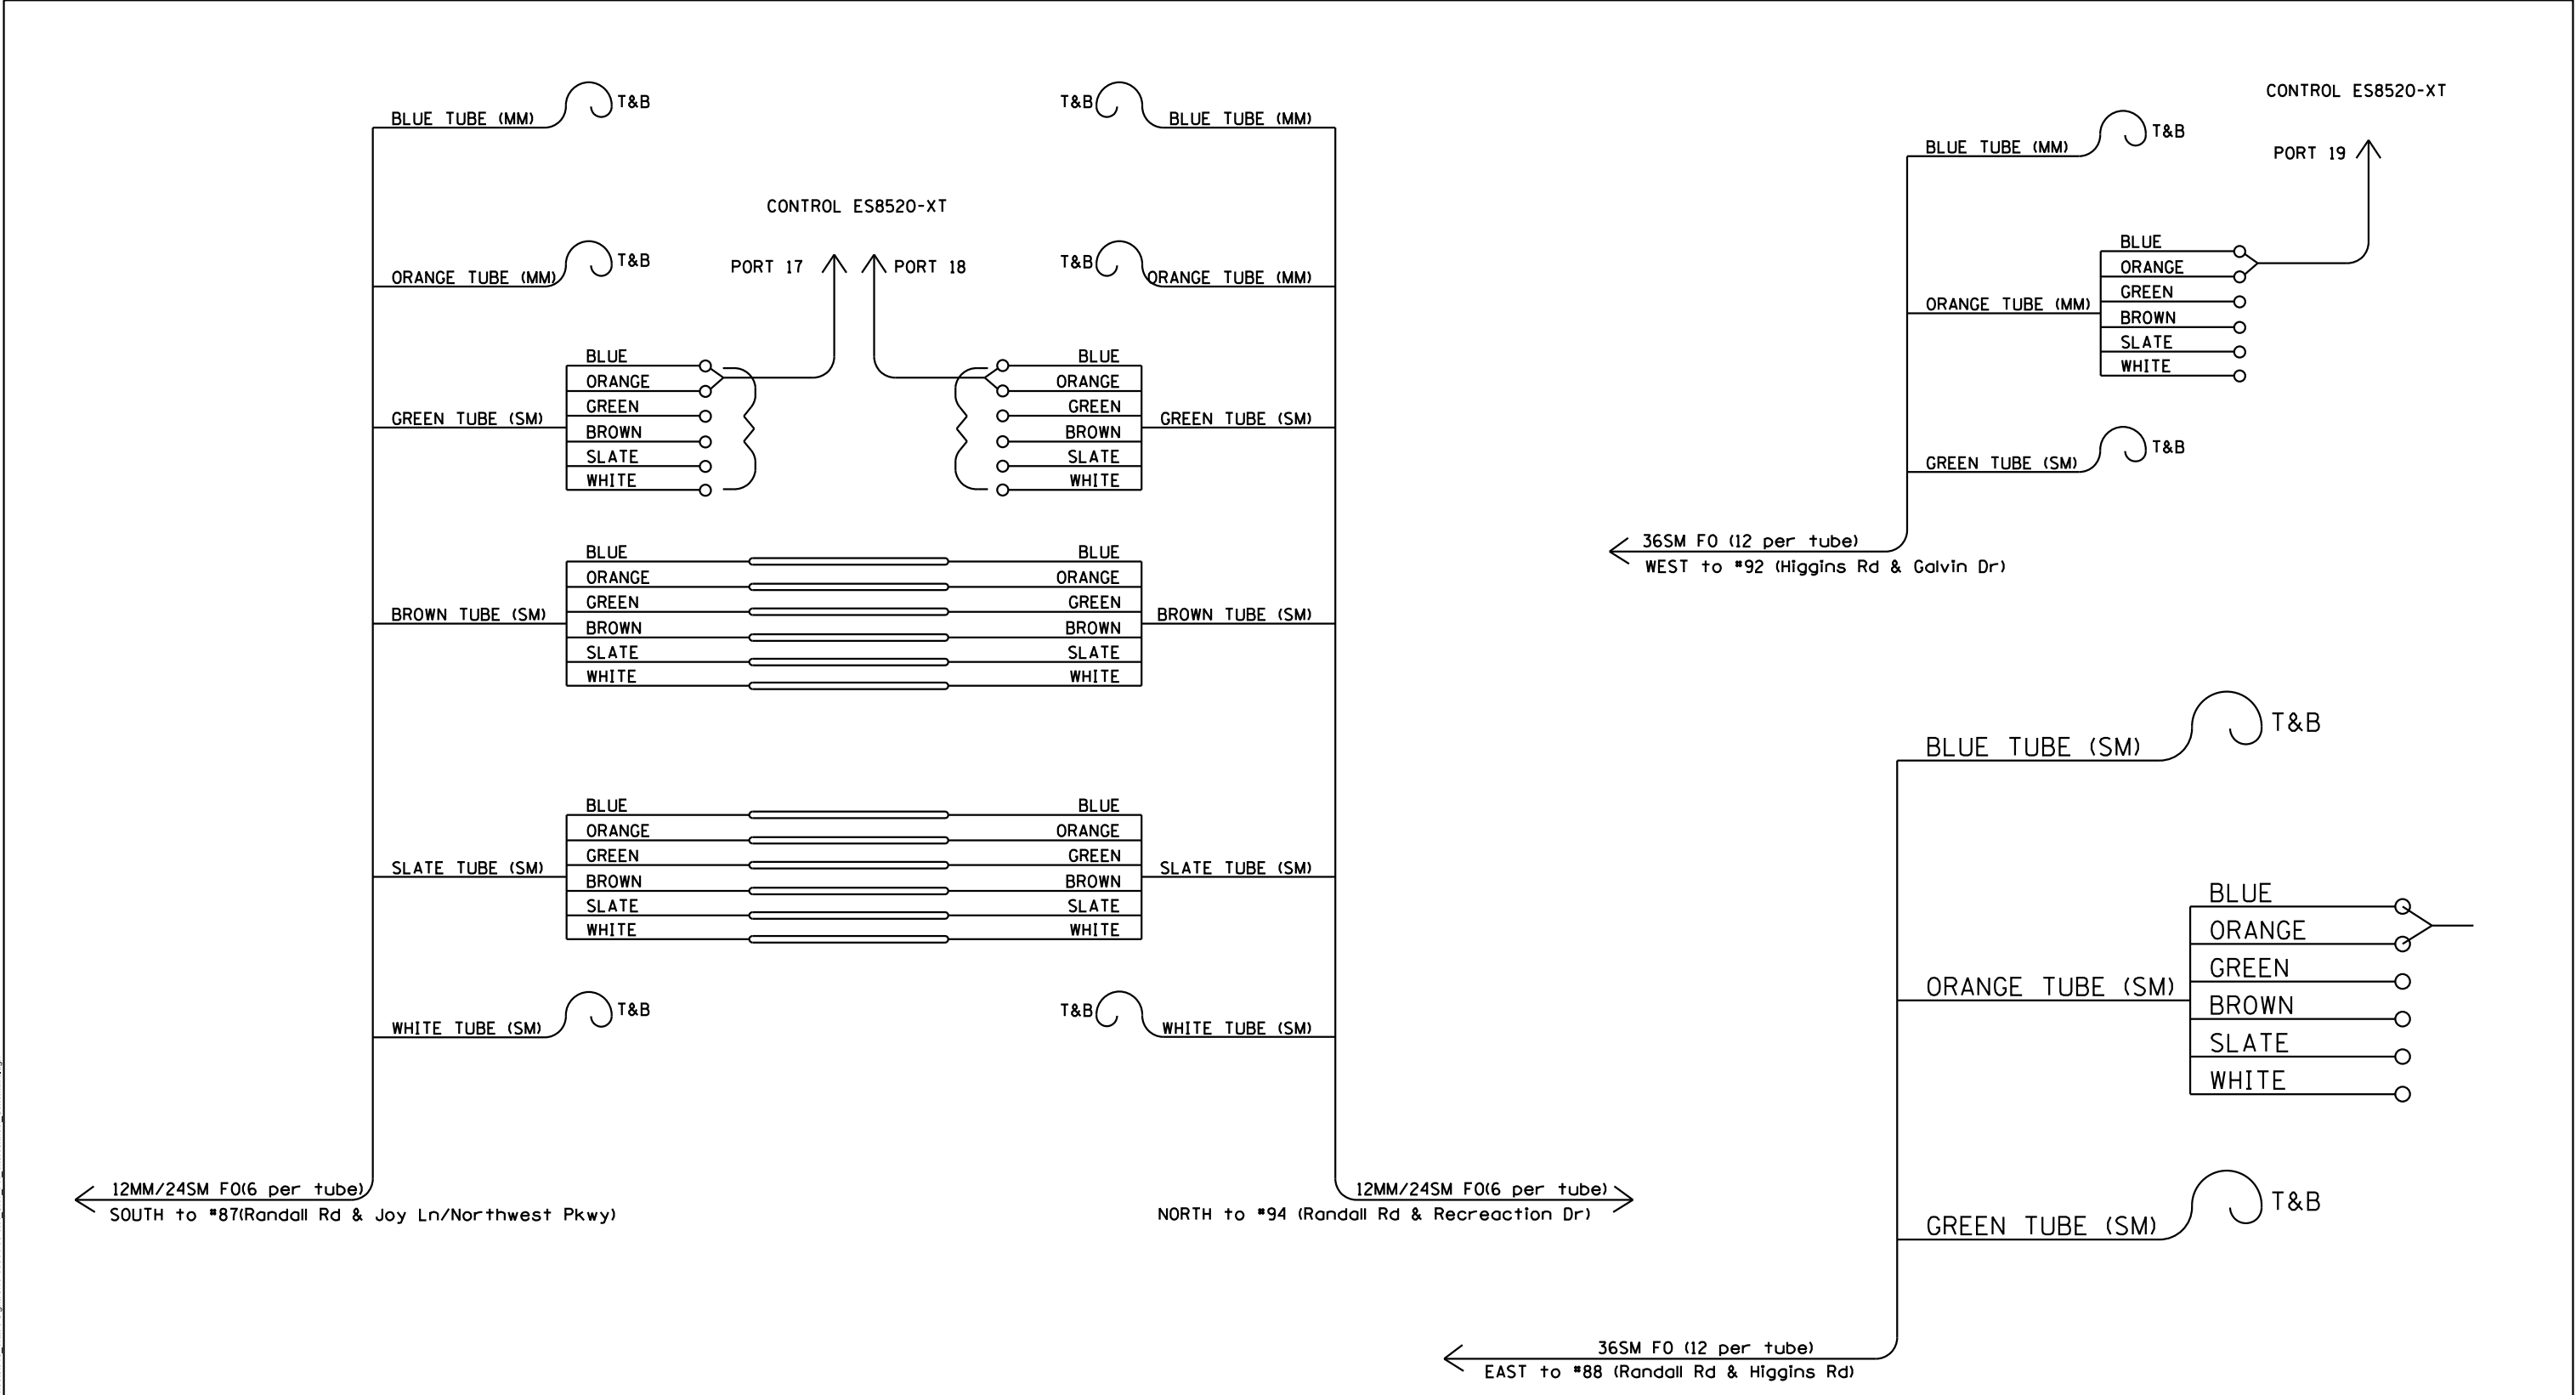

FOR INFORMATION ONLY



BLA, Inc.

USER NAME = tnestor	DESIGNED - TN	REVISED -
	DRAWN - TN	REVISED -
PLOT SCALE = 100.0000' / in.	CHECKED - GJE	REVISED -
PLOT DATE = 8/21/2025	DATE - 02/15/2025	REVISED -

STATE OF ILLINOIS
DEPARTMENT OF TRANSPORTATION

RANDALL ROAD AT IL ROUTE 72 (HIGGINS ROAD)

SCALE: SHEET OF SHEETS STA. TO STA.

F.A.P. RTE.	SECTION	COUNTY	TOTAL SHEETS	SHEET NO.
0336	19-00514-00-WR	KANE	304	192
CONTRACT NO. 61L28				
ILLINOIS FED. AID PROJECT				

KDOT SYSTEM

MODEL: Default
FILE NAME: V:\894-088 Randall at Higgins Phase II Engineering\CADD Sheets\016 Traffic Signals\19-00514-00-WR_SHT_FR_Interconnect_Schematic.dgn



BLA, Inc.

USER NAME = tnestor	DESIGNED - TN	REVISED -
	DRAWN - TN	REVISED -
PLOT SCALE = 100.0000' / in.	CHECKED - GJE	REVISED -
PLOT DATE = 8/21/2025	DATE - 02/15/2025	REVISED -


STATE OF ILLINOIS
DEPARTMENT OF TRANSPORTATION

RANDALL ROAD AT IL ROUTE 72 (HIGGINS ROAD)
ETHERNET SCHEMATIC


SCALE: SHEET OF SHEETS STA. TO STA.

F.A.P. RTE.	SECTION	COUNTY	TOTAL SHEETS	SHEET NO.
0336	19-00514-00-WR	KANE	304	193
CONTRACT NO. 61L28				
ILLINOIS FED. AID PROJECT				


KDOT SYSTEM

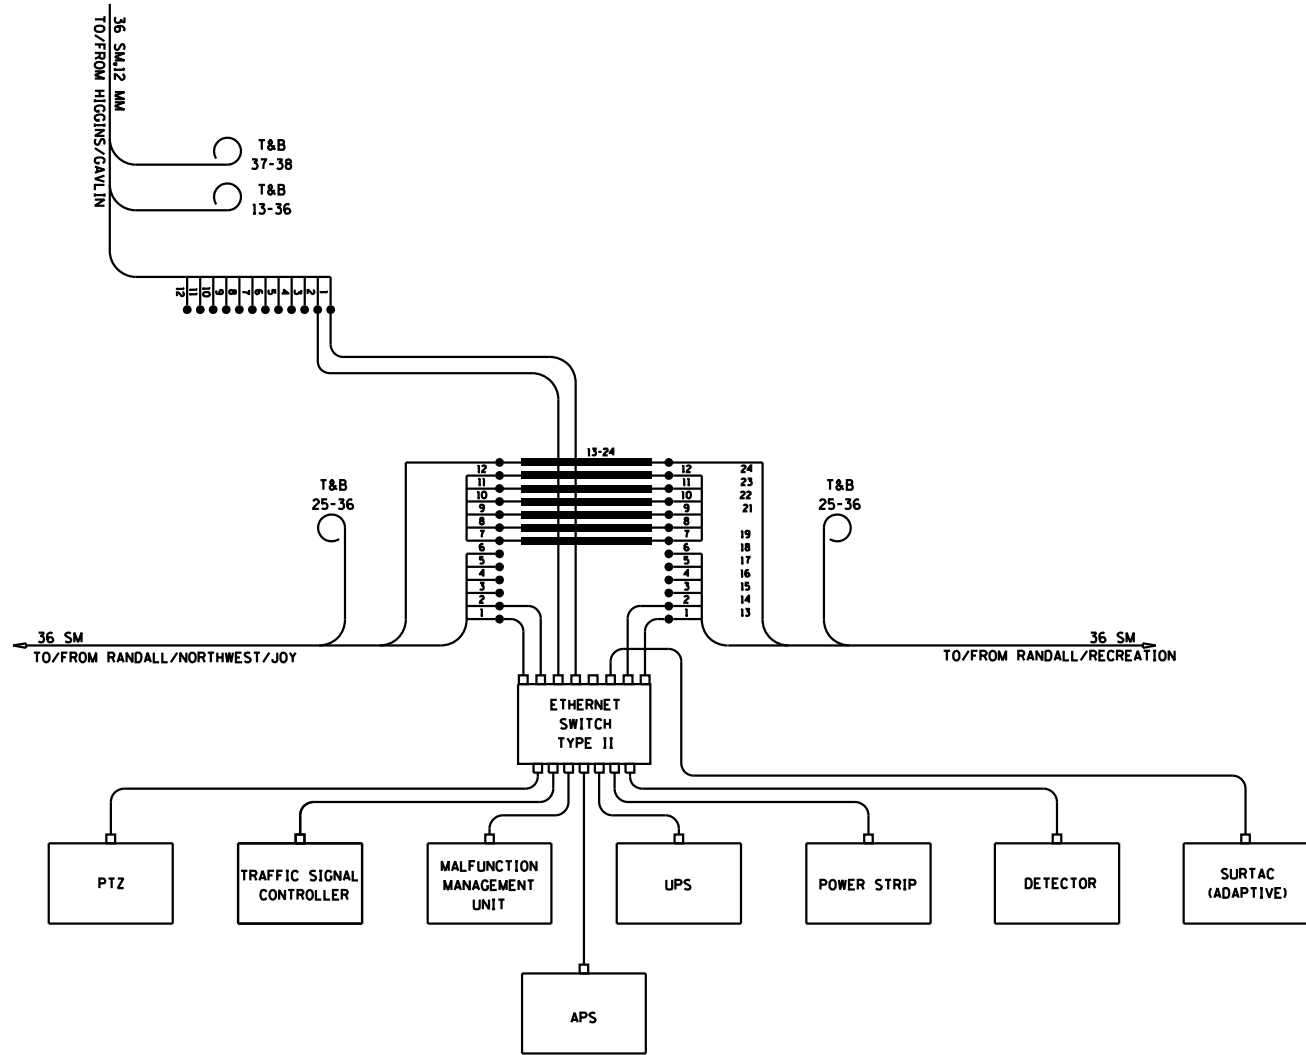


RANDALL ROAD AT IL ROUTE 72 (HIGGINS ROAD)

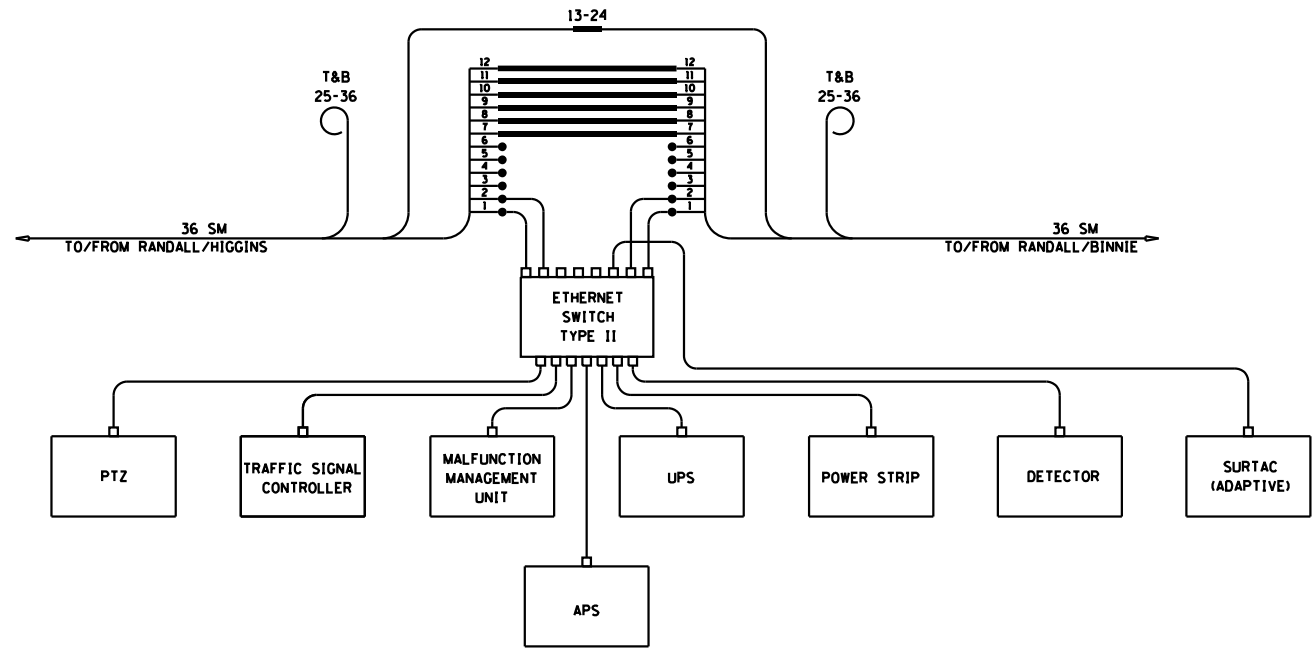

RANDALL ROAD AT RECREATION DRIVE

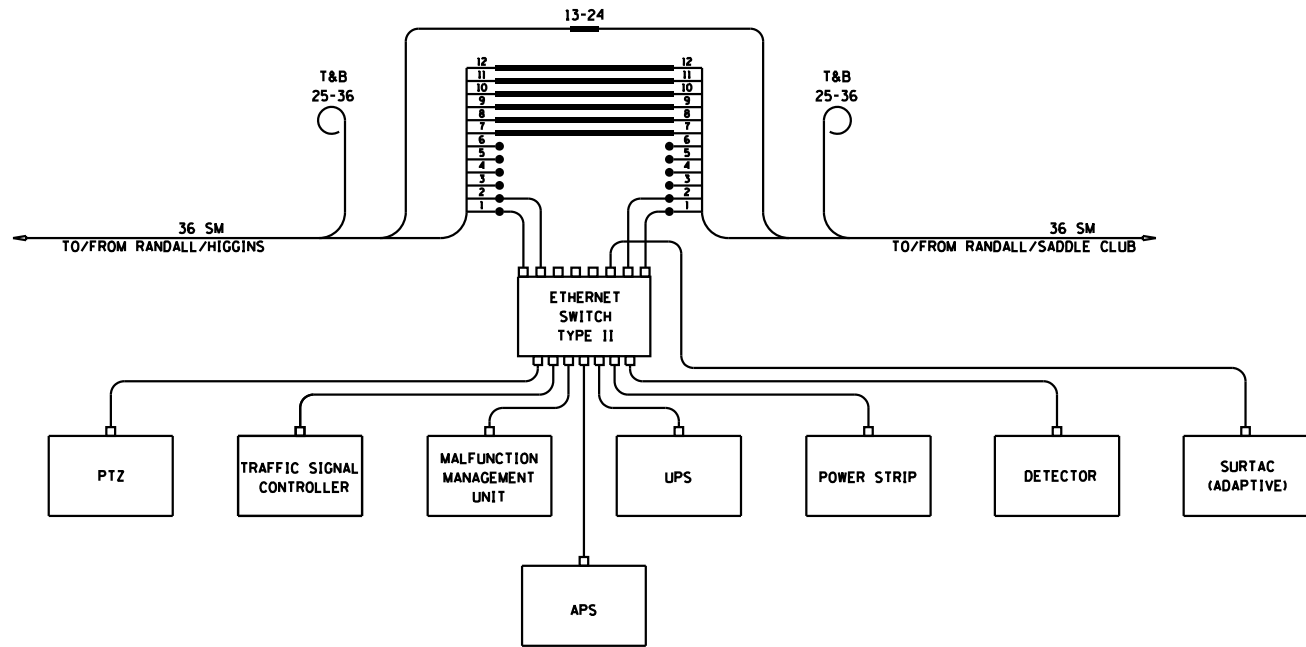


RANDALL ROAD AT NORTHWEST PARKWAY/JOY LANE

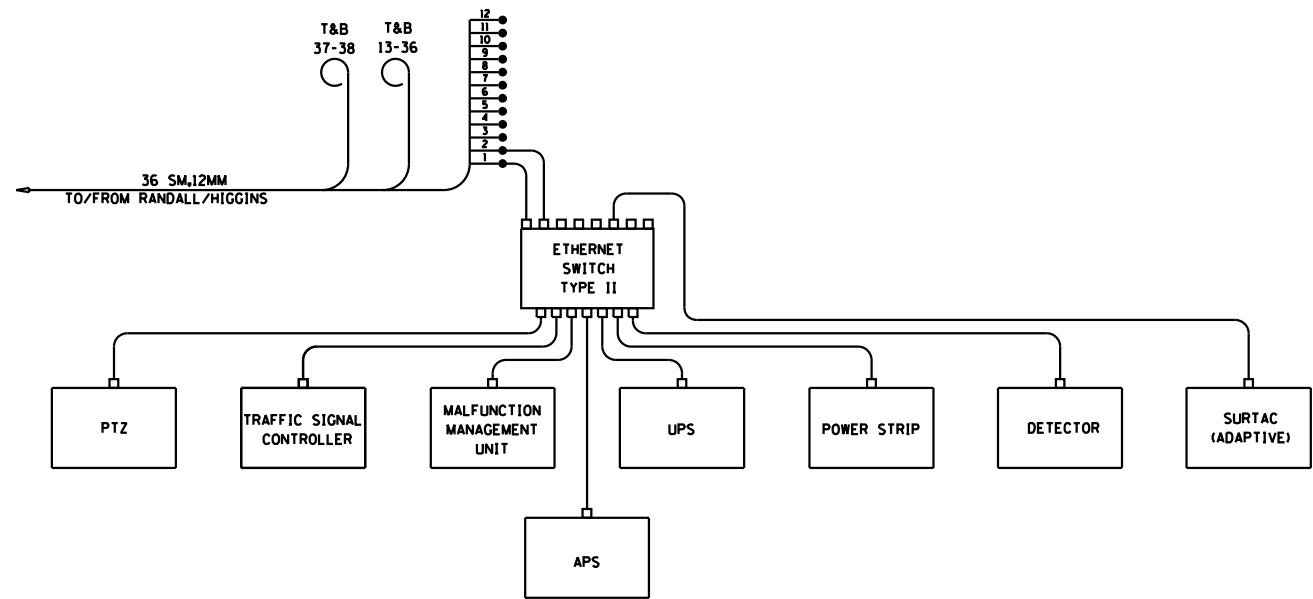

IL ROUTE 72 (HIGGINS ROAD) AT GALVIN ROAD

Intersection ID #94 - Randall Rd & Recreation Dr
Splice & Termination Detail

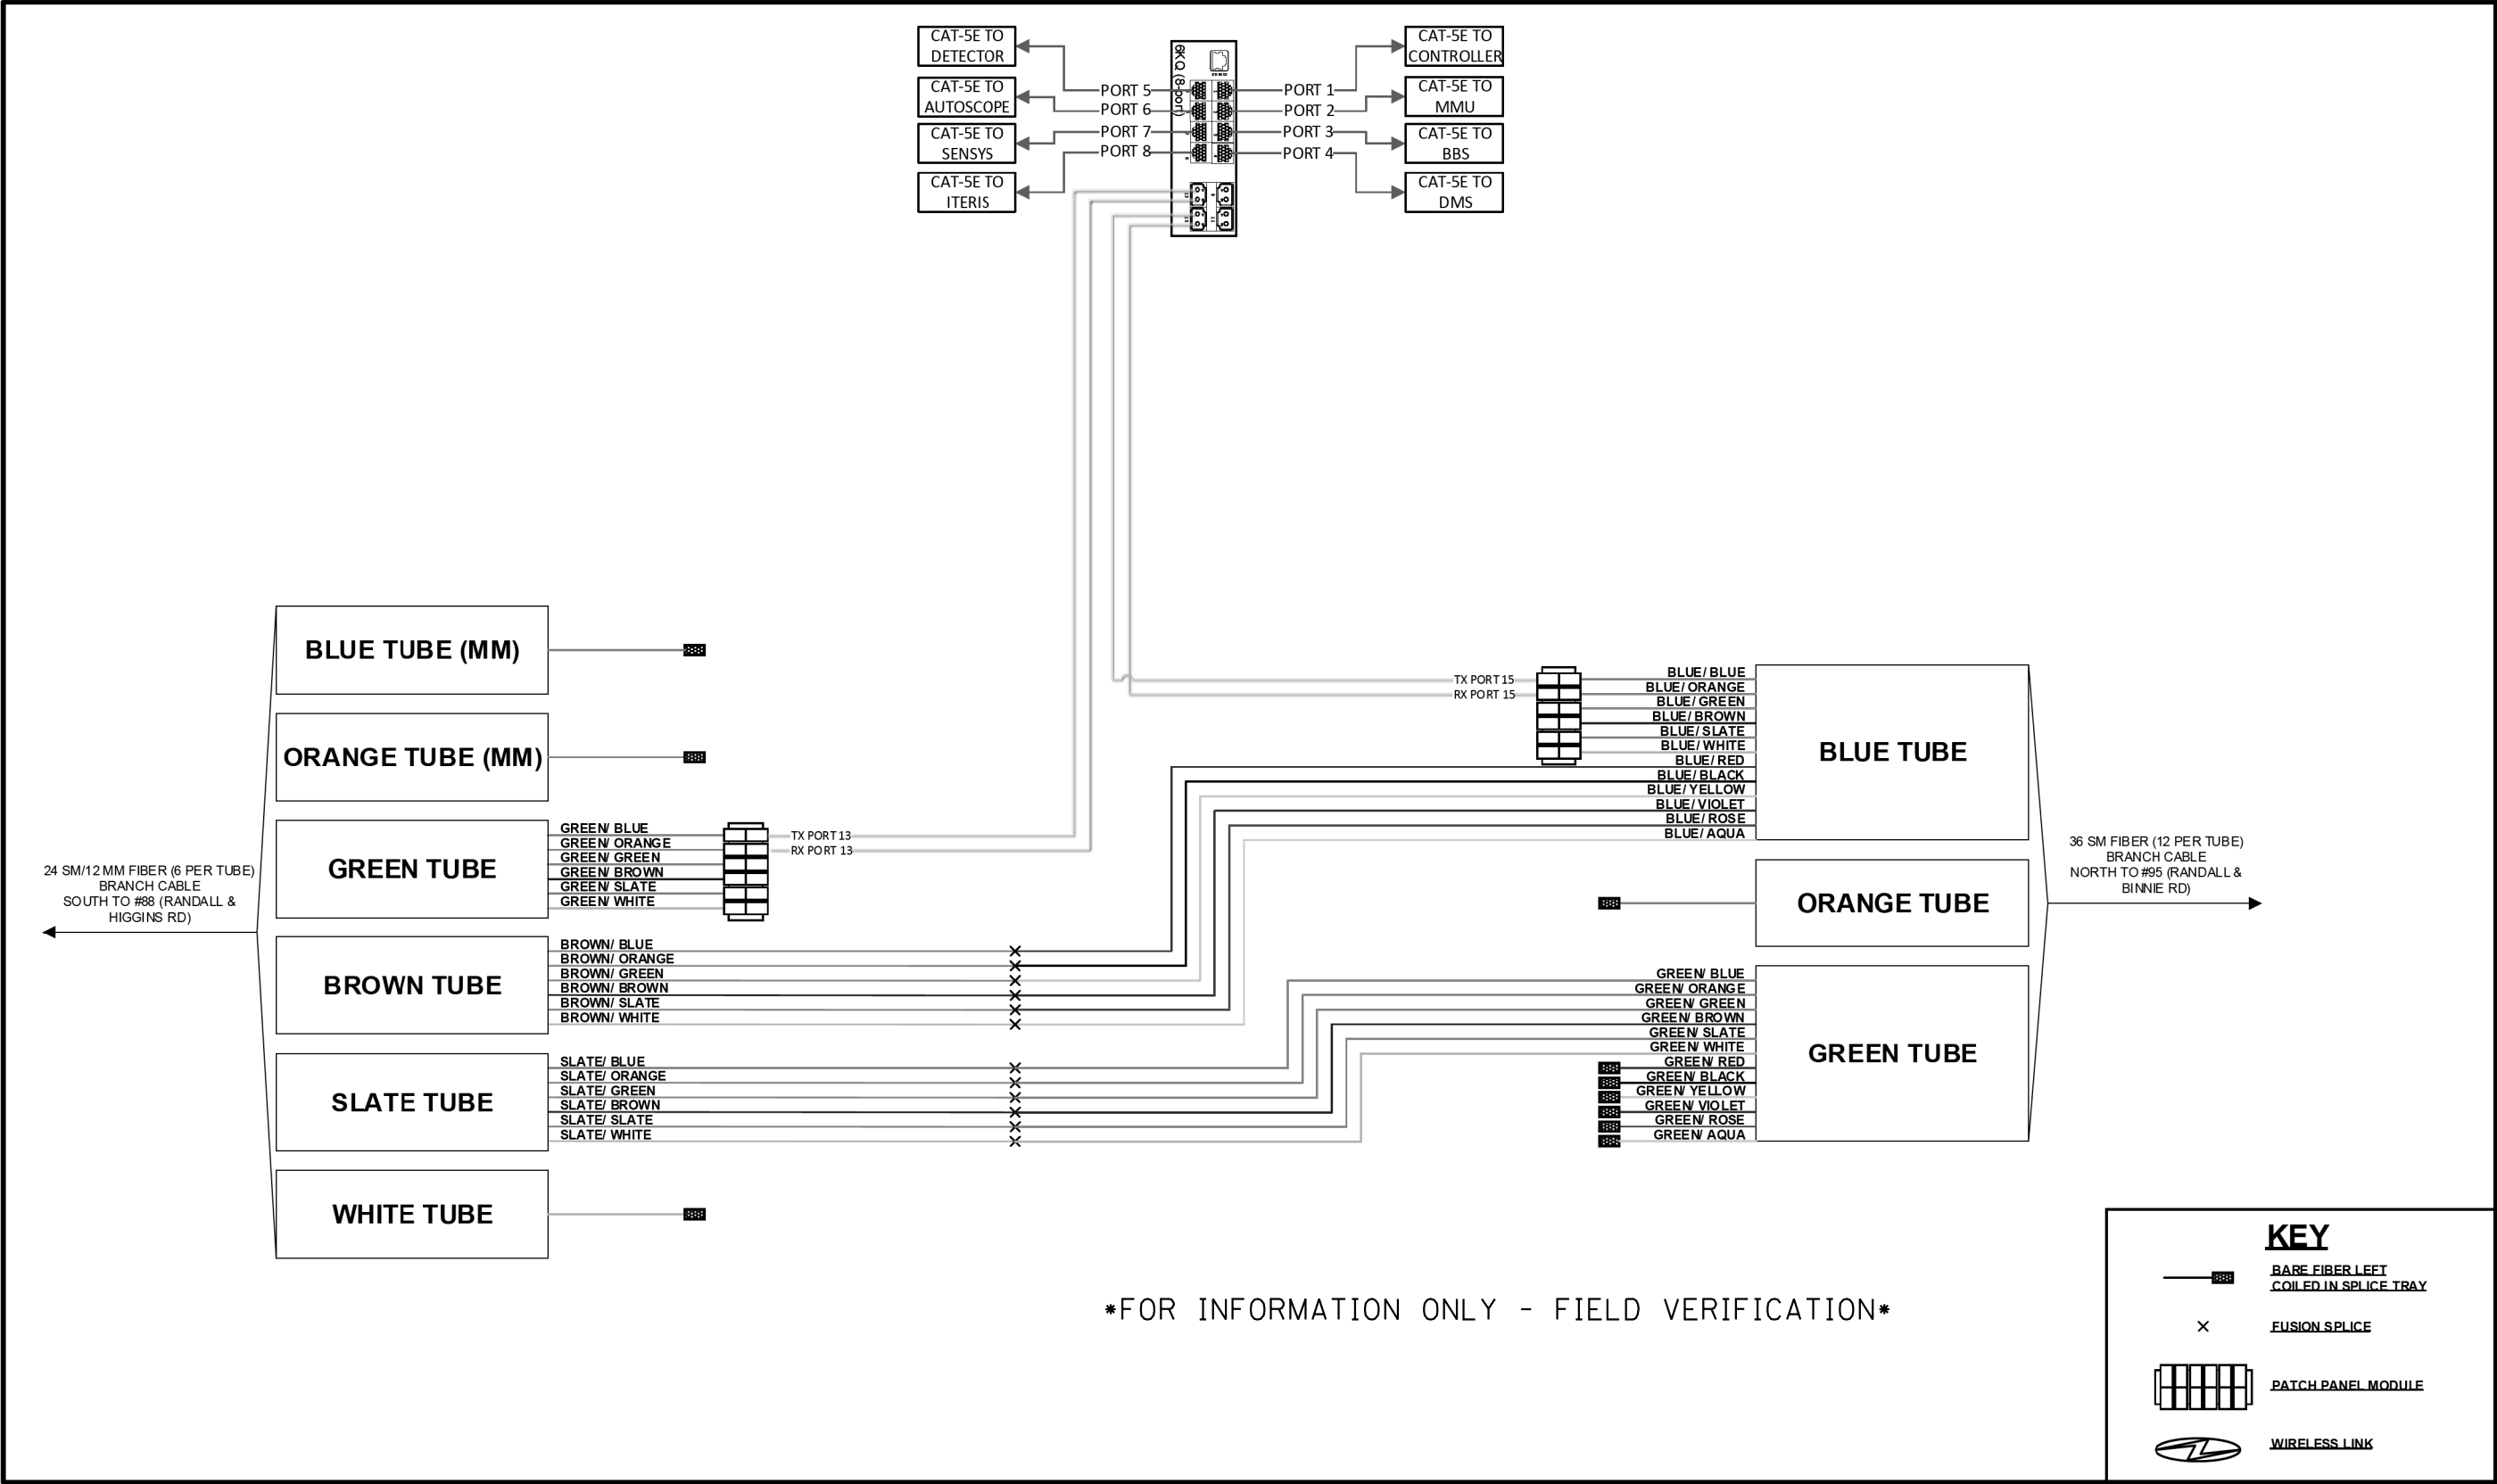

MODEL: Default
FILE NAME: V:\894-088 Randall at Higgins Phase II Engineering\CADD Sheets\016 Traffic Signals\19-00514-00-WR_SHT_FR_Interconnect_Schematic.dgn



BLA, Inc.

USER NAME = tnestor	DESIGNED - TN	REVISED -
PLOT SCALE = 100.0000' / in.	DRAWN - TN	REVISED -
PLOT DATE = 8/21/2025	CHECKED - GJE	REVISED -
	DATE - 02/15/2025	REVISED -

STATE OF ILLINOIS
DEPARTMENT OF TRANSPORTATION


RANDALL ROAD AT IL ROUTE 72 (HIGGINS ROAD)

SCALE: SHEET OF SHEETS STA. TO STA.

F.A.P. RTE.	SECTION	COUNTY	TOTAL SHEETS	SHEET NO.
0336	19-00514-00-WR	KANE	304	194
CONTRACT NO. 61L28				
ILLINOIS FED. AID PROJECT				

KDOT SYSTEM

Intersection ID #88 - Randall Rd & Higgins Rd
Splice & Termination Detail

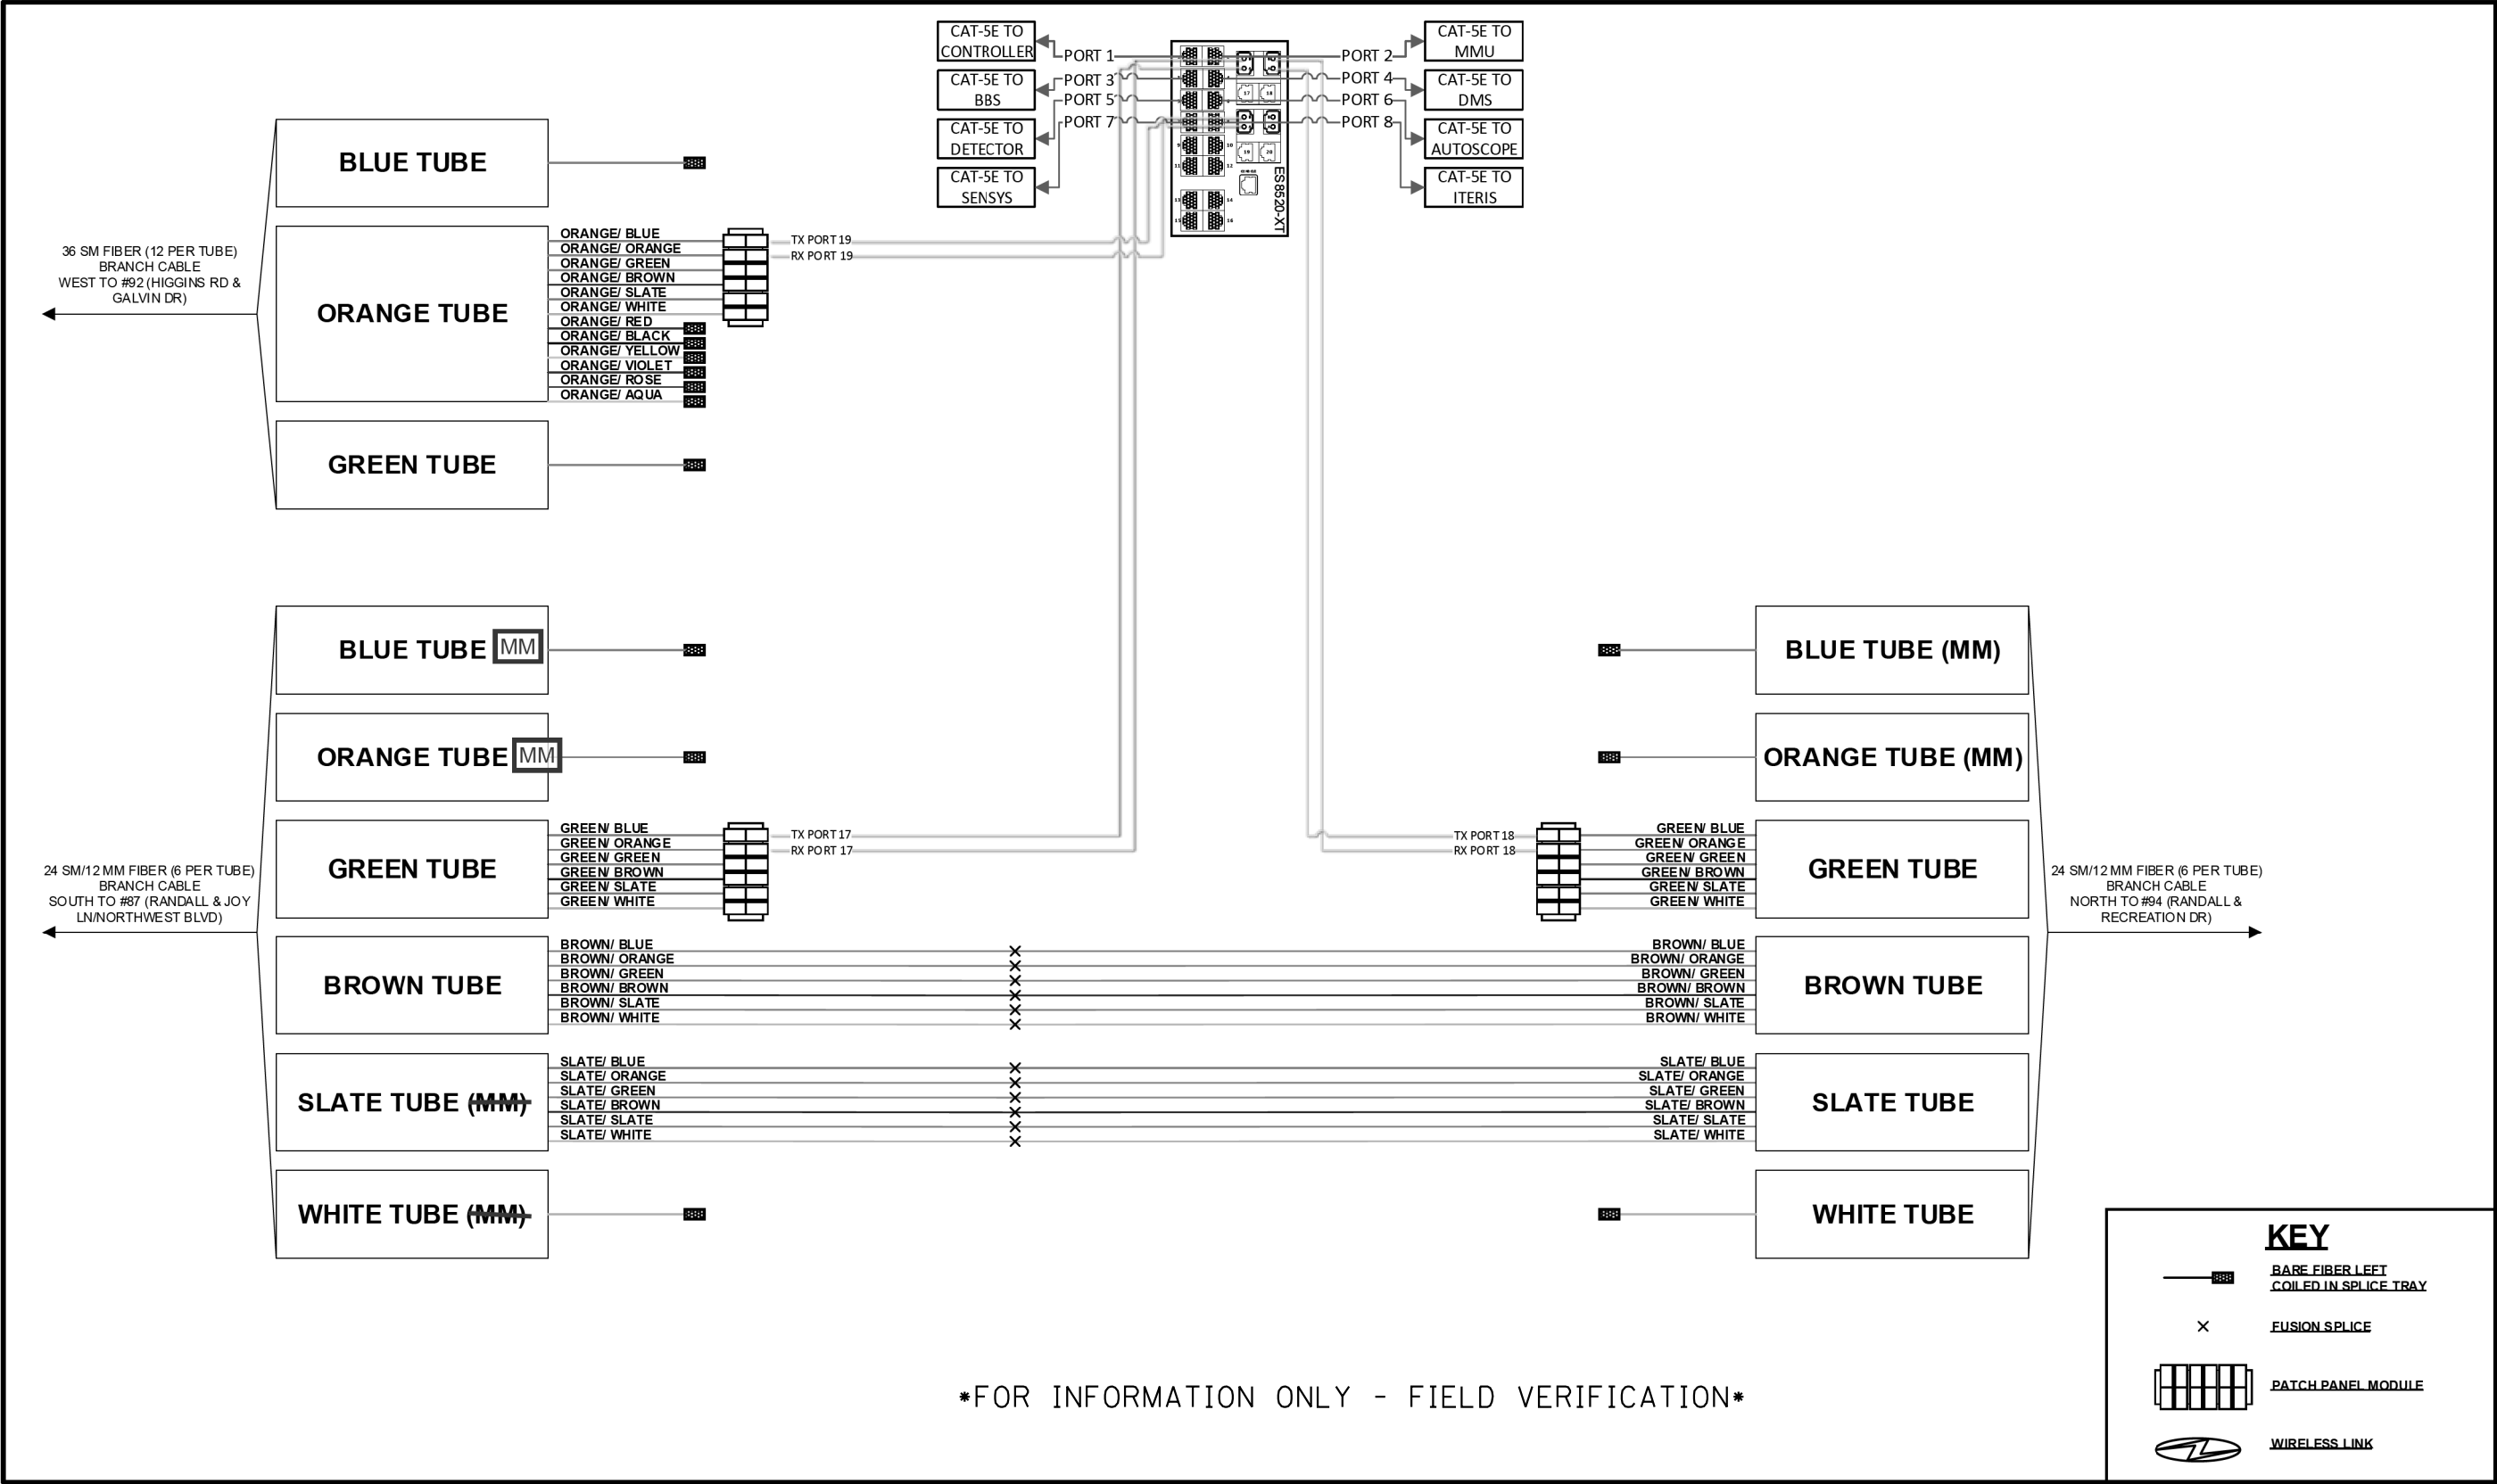

MODEL: Default
FILE NAME: V:\894-088 Randall at Higgins Phase II Engineering\CADD Sheets\016 Traffic Signals\19-00514-00-WR_SHT_FR Fiberconnect_Schematic.dgn



BLA, Inc.

USER NAME = tnestor	DESIGNED - TN	REVISED -
PLOT SCALE = 100.0000' / in.	DRAWN - TN	REVISED -
PLOT DATE = 8/21/2025	CHECKED - GJE	REVISED -
	DATE - 02/15/2025	REVISED -

STATE OF ILLINOIS
DEPARTMENT OF TRANSPORTATION


RANDALL ROAD AT IL ROUTE 72 (HIGGINS ROAD)

SCALE: SHEET OF SHEETS STA. TO STA.

F.A.P. RTE.	SECTION	COUNTY	TOTAL SHEETS	SHEET NO.
0336	19-00514-00-WR	KANE	304	195
CONTRACT NO. 61L28				
ILLINOIS FED. AID PROJECT				

KDOT SYSTEM

Intersection ID #87 - Randall Rd & Joy Ln/ Northwest Blvd
Splice & Termination Detail

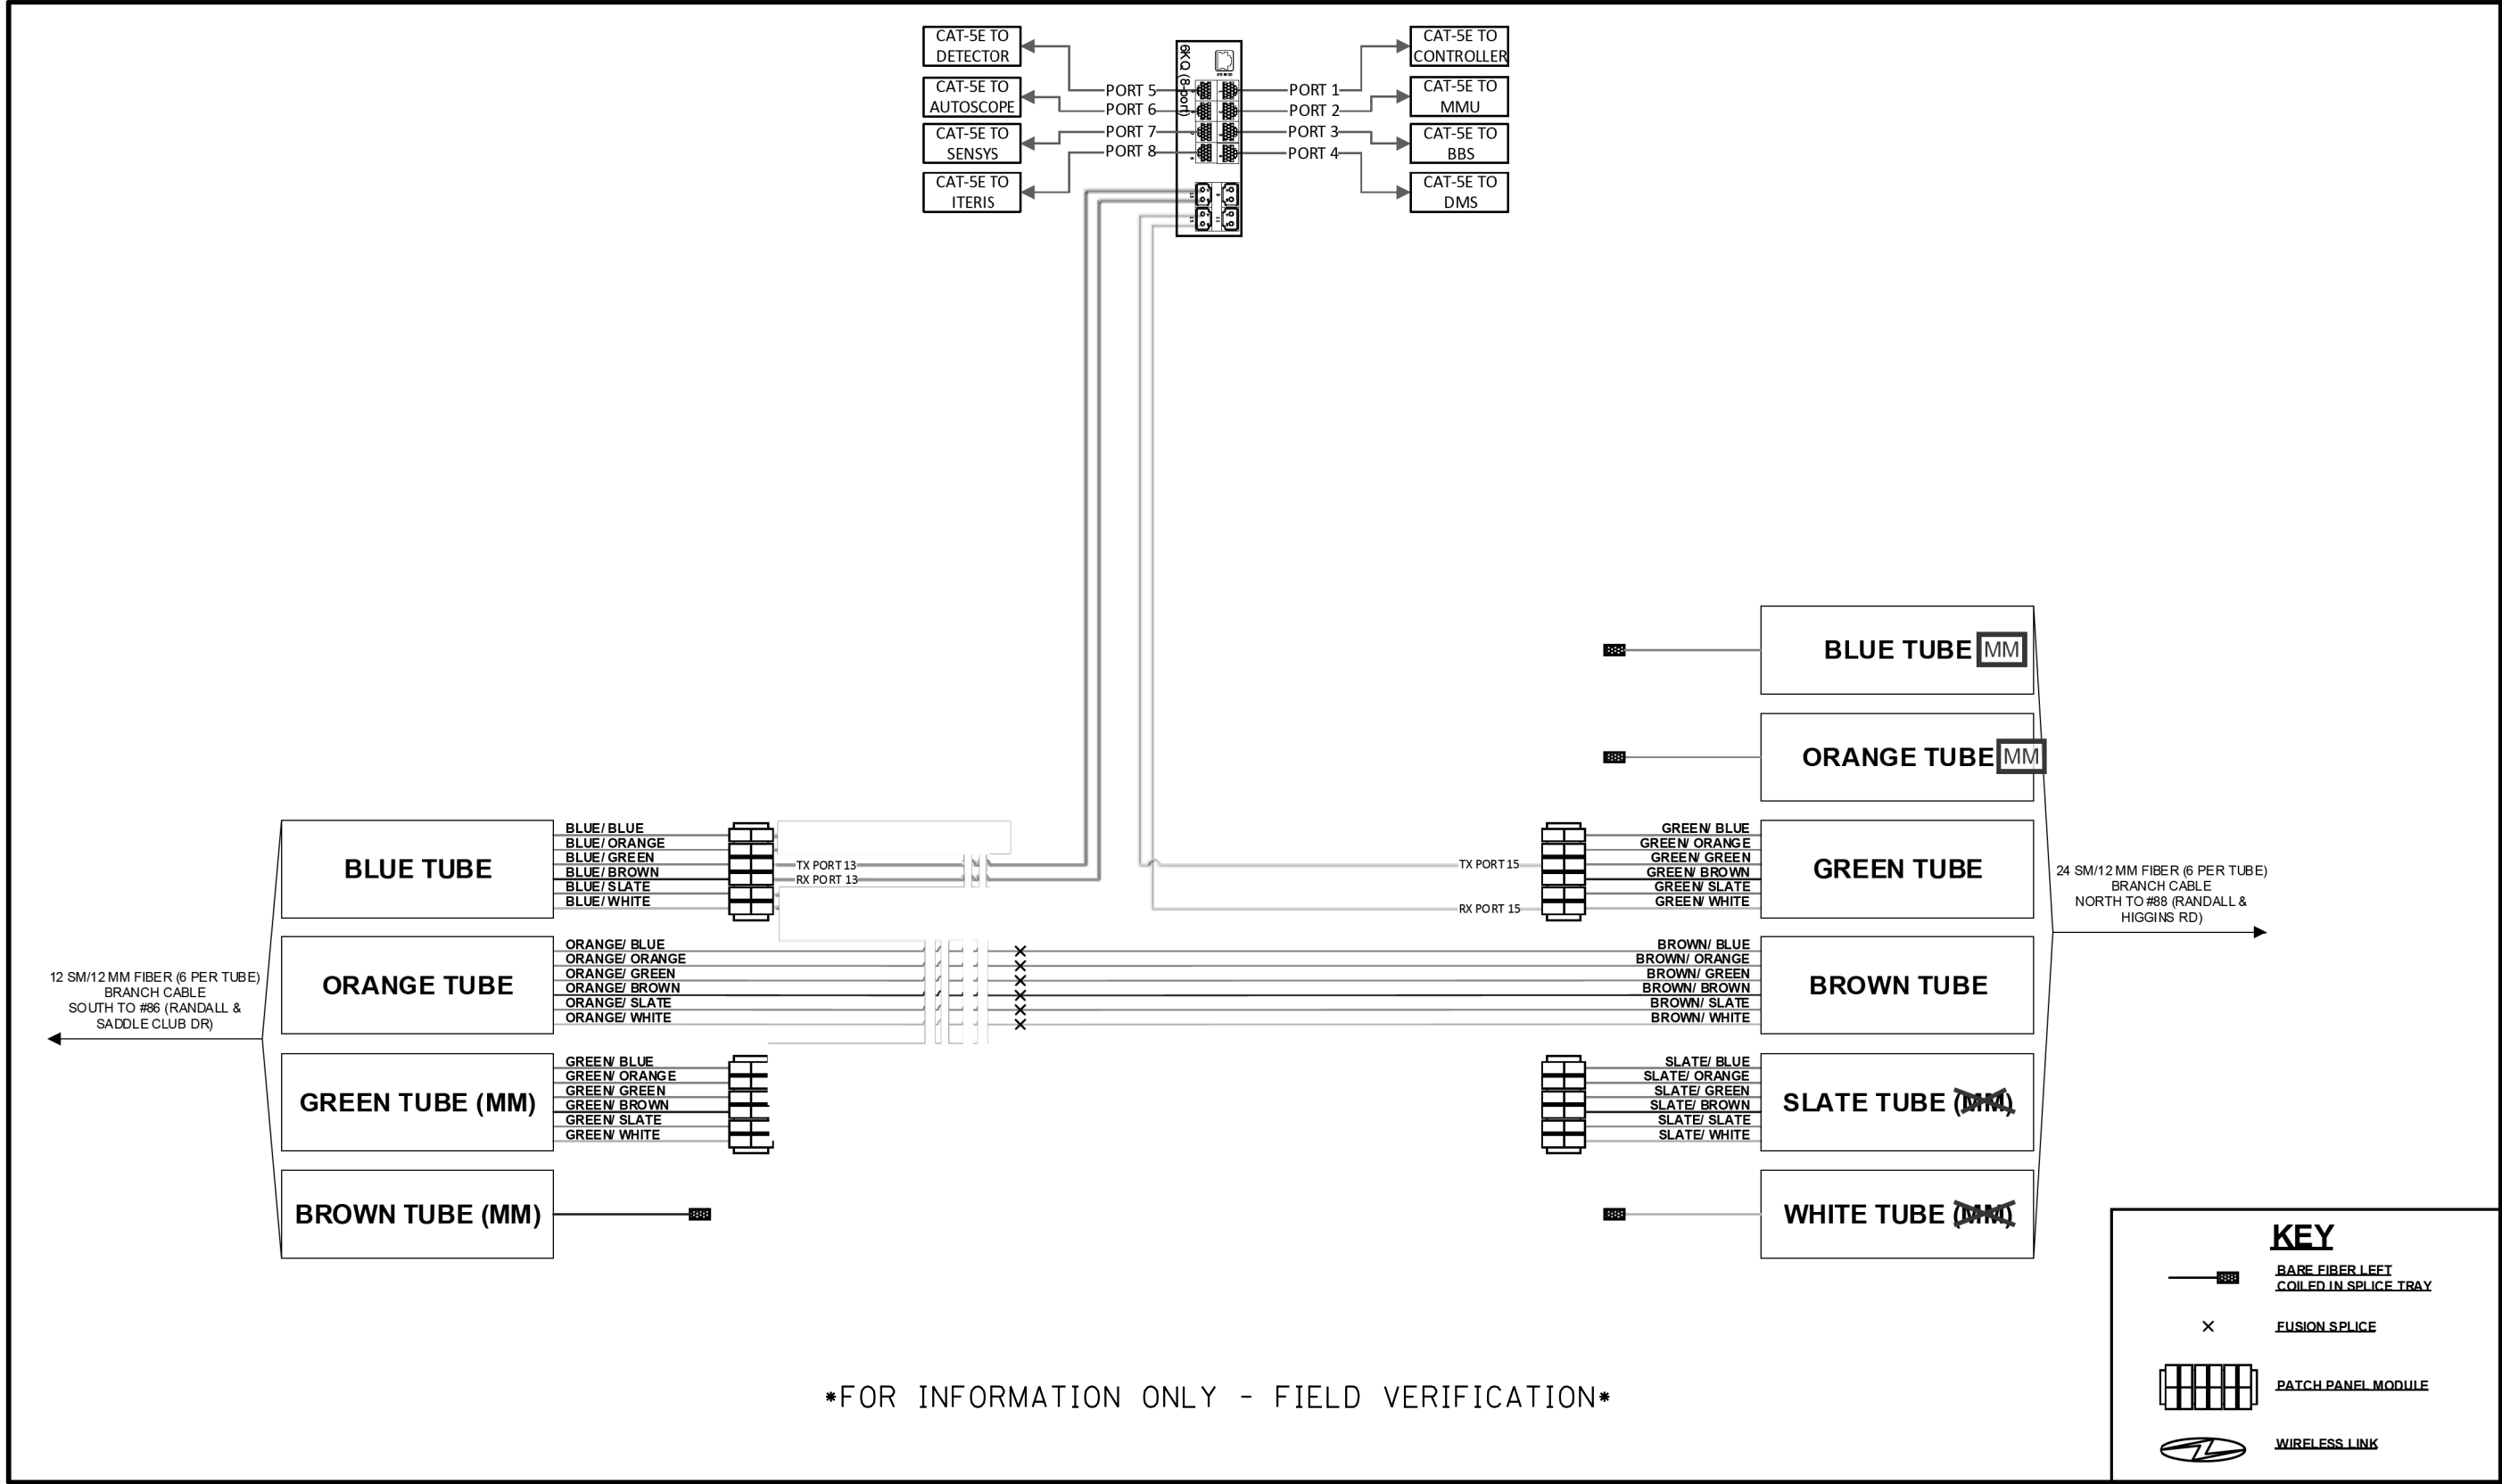

FOR INFORMATION ONLY - FIELD VERIFICATION

MODEL: Default
FILE NAME: V:\894-088 Randall at Higgins Phase II Engineering\CADD Sheets\016 Traffic Signals\19-00514-00-WR_SHT_FR_Interconnect_Schematic.dgn



BLA, Inc.

USER NAME = tnestor	DESIGNED - TN	REVISED -
PLOT SCALE = 100.0000' / in.	DRAWN - TN	REVISED -
PLOT DATE = 8/21/2025	CHECKED - GJE	REVISED -
	DATE - 02/15/2025	REVISED -

STATE OF ILLINOIS
DEPARTMENT OF TRANSPORTATION


RANDALL ROAD AT IL ROUTE 72 (HIGGINS ROAD)

SCALE: SHEET OF SHEETS STA. TO STA.

F.A.P. RTE.	SECTION	COUNTY	TOTAL SHEETS	SHEET NO.
0336	19-00514-00-WR	KANE	304	196
CONTRACT NO. 61L28				
ILLINOIS FED. AID PROJECT				

KDOT SYSTEM

Intersection ID #92 - Higgins Rd & Galvin Dr
Splice & Termination Detail

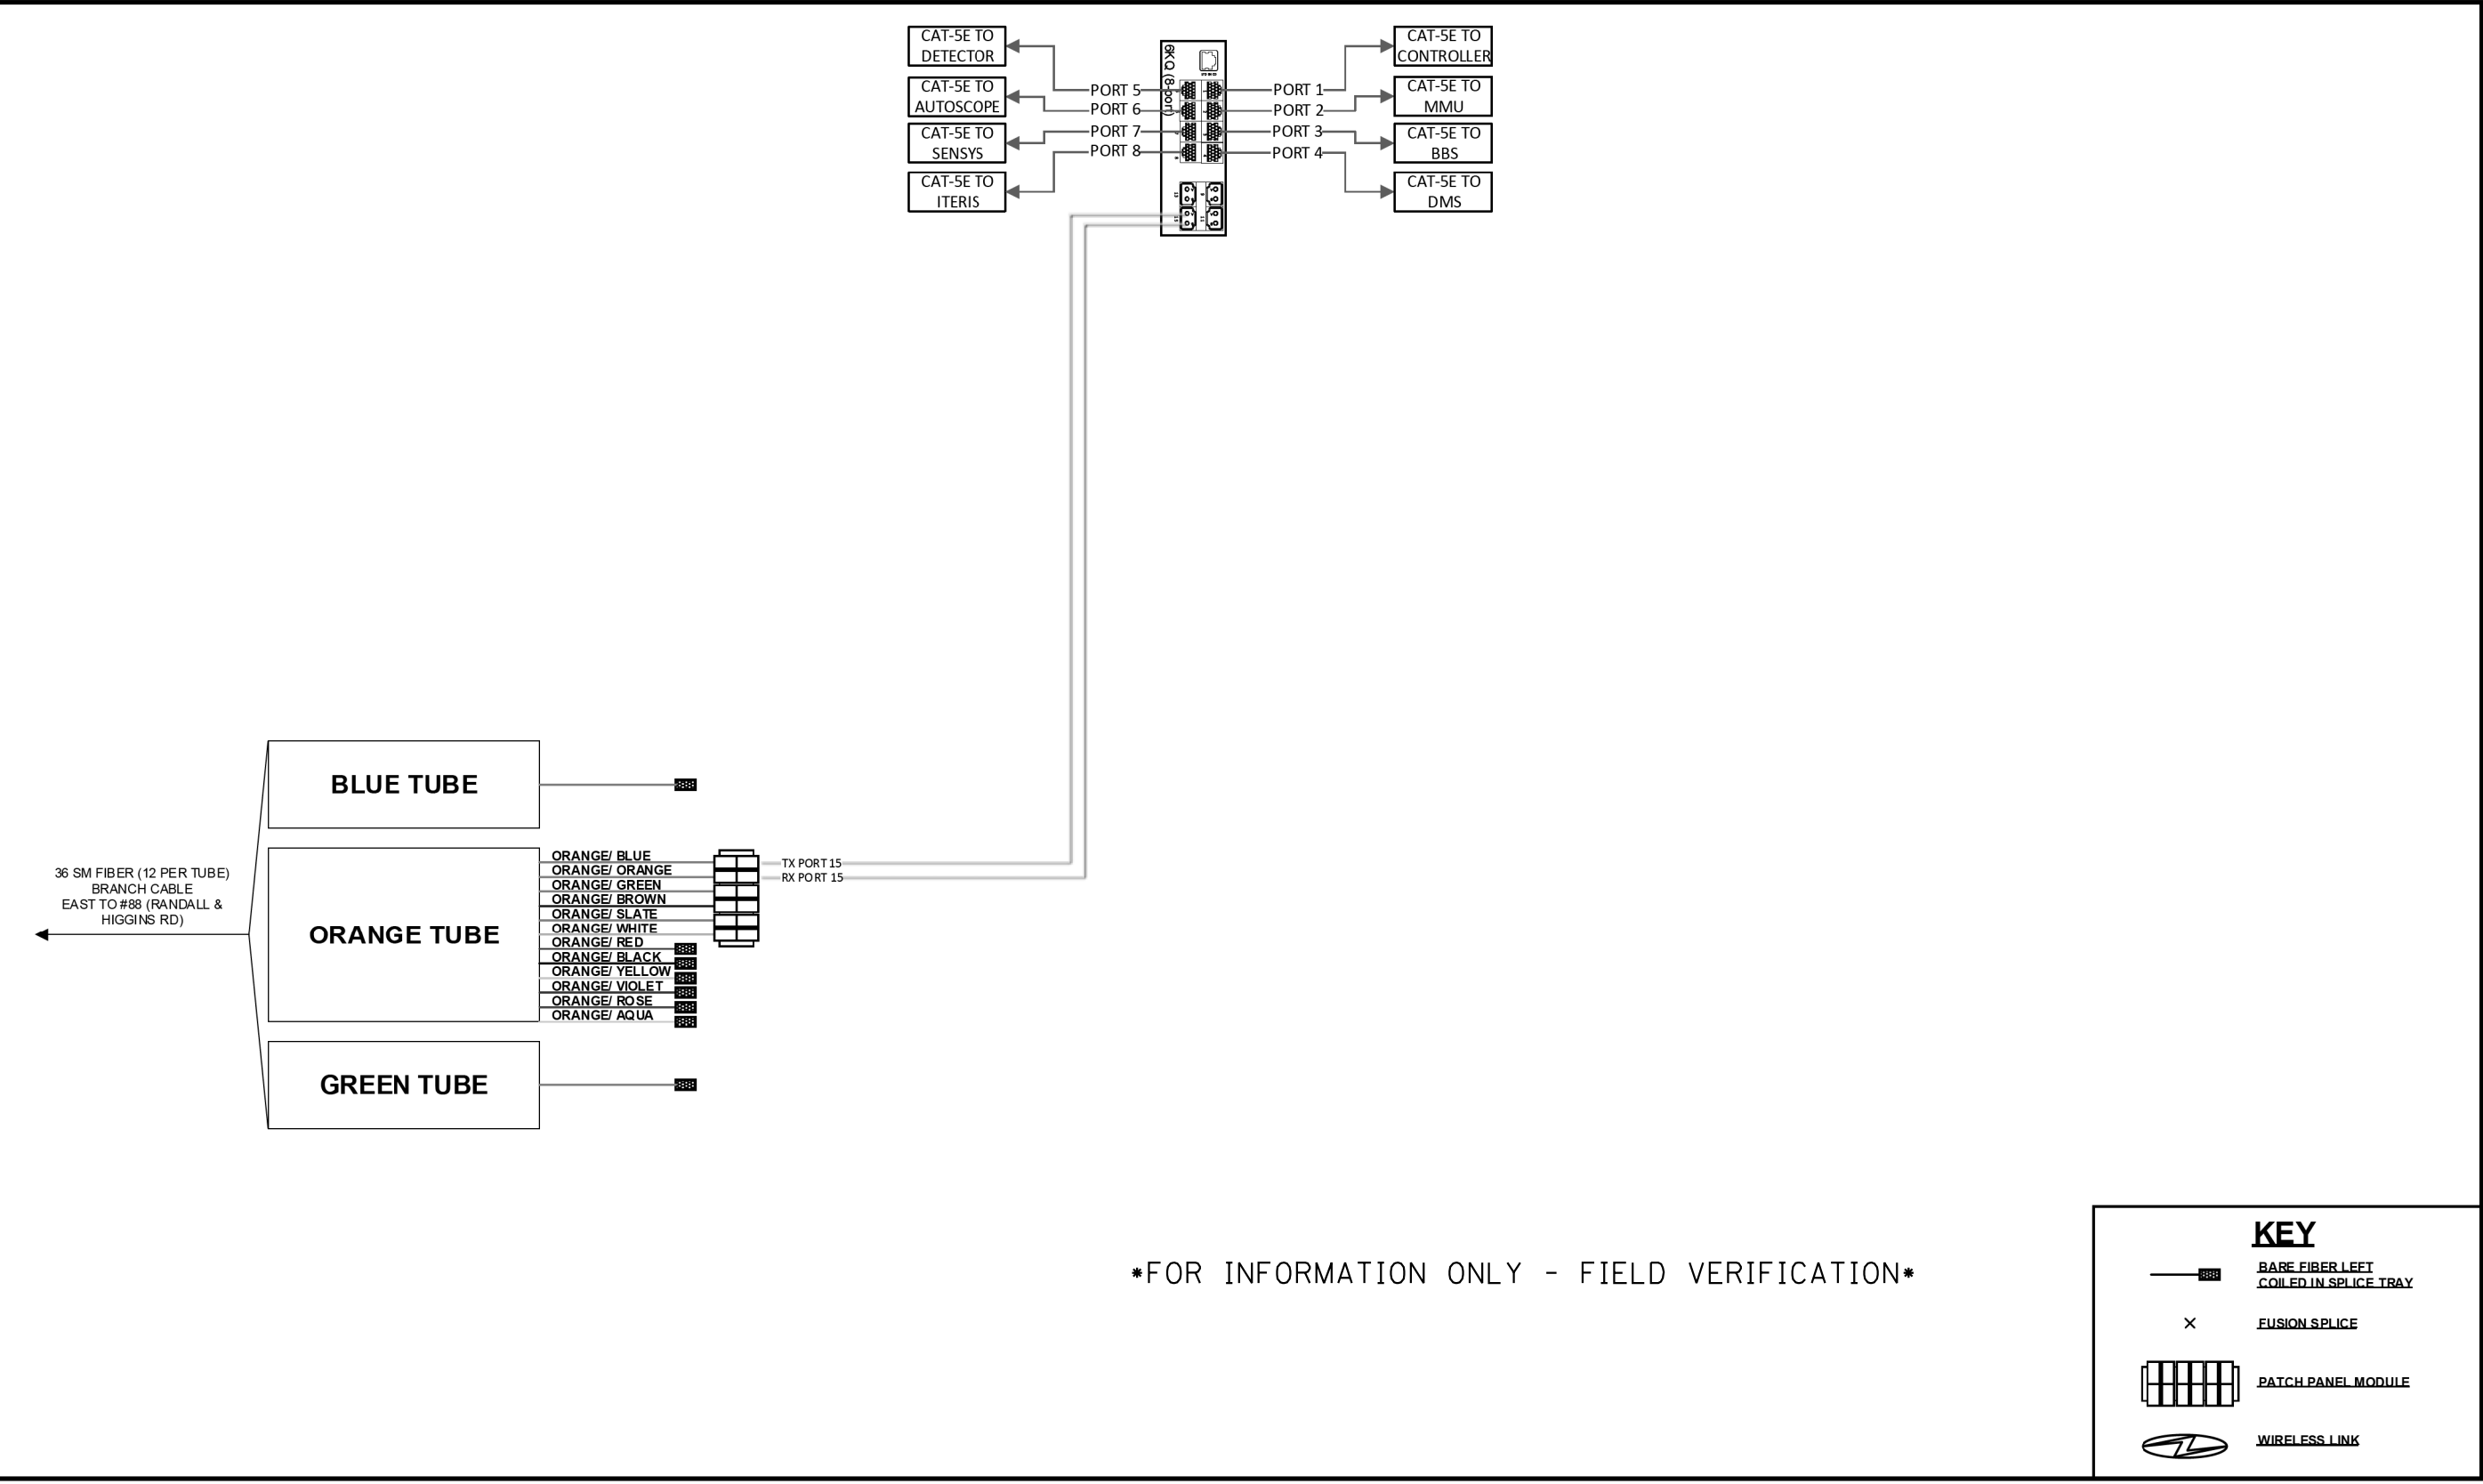

FOR INFORMATION ONLY - FIELD VERIFICATION

KEY

- BARE FIBER LEFT COILED IN SPLICE TRAY
- FUSION SPLICE
- PATCH PANEL MODULE
- WIRELESS LINK

GENERAL NOTES:

1.

THIS PROJECT INCLUDES THE REPLACEMENT OF THE EXISTING ROADWAY LIGHTING AT THE INTERSECTION OF RANDALL ROAD AND IL ROUTE 72. THE PROPOSED LIGHTING SHALL BE ENERGIZED, OWNED, AND MAINTAINED BY ILLINOIS DEPARTMENT OF TRANSPORTATION. NEW COMBINATION LIGHTING WILL BE INSTALLED WITH THE NEW TRAFFIC SIGNALS AND THIS COMBINATION LIGHTING SHALL BE OWNED AND MAINTAINED BY ILLINOIS DEPARTMENT OF TRANSPORTATION.
2.

THE CONTRACTOR SHALL CONTACT THE ELECTRIC UTILITY COMPANY TO COORDINATE THE ELECTRIC SERVICE WORK. ILLINOIS DEPARTMENT OF TRANSPORTATION SHALL BE CONTACTED TO TRANSFER STATE MAINTAINED EQUIPMENT TO THE CONTRACTOR BEFORE THE START OF ANY WORK.
3.

THE QUANTITIES OF RACEWAY WHERE INDICATED ON THESE PLANS ARE APPROXIMATIONS ONLY. THE CONTRACTOR SHALL FIELD VERIFY ALL LENGTHS AND SHALL INSTALL RACEWAYS IN COMPLETE COMPLIANCE WITH THE SPECIFIED REQUIREMENTS.
4.

THE CONTRACTOR SHALL NOTIFY J.U.L.I.E. TO LOCATE AND MARK/STAKE ALL UNDERGROUND UTILITIES. MEADE ELECTRIC CO., DISTRICT 1 ELECTRICAL MAINTENANCE CONTRACTOR LOCATES IDOT ELECTRICAL EQUIPMENT AND UNDERGROUND CABLES. CALL MEADE ELECTRIC CO. TO TRANSFER IDOT MAINTAINED EQUIPMENT TO THE CONTRACTOR BEFORE THE START OF ANY WORK. THEIR PHONE NUMBER IS 773-287-7672.
5.

THE CONTRACTOR SHALL VERIFY LOCATIONS OF UNDERGROUND/OVERHEAD UTILITIES PRIOR TO INSTALLATION OF LIGHT POLES AND CONDUITS. IF THERE IS A CONFLICT WITH THE LIGHT POLES/CONDUITS AS SHOWN ON PLANS, THE CONTRACTOR SHALL SUGGEST ALTERNATIVE LOCATIONS AND COORDINATE WITH THE ENGINEER PRIOR TO PERFORMING ANY CONSTRUCTION WORK.
6.

TRENCHES FOR LIGHTING RACEWAYS SHALL HAVE A MINIMUM DEPTH OF 30".
7.

LIGHTING SYSTEM INSTALLATION SHALL CONFORM TO THE LATEST IDOT STANDARDS, KANE COUNTY STANDARDS, NEC AND LOCAL CODES.
8.

ALL ELECTRICAL EQUIPMENT AND PRODUCTS SHALL BE NEW UL LISTED AND LABELED.
9.

THE CONTRACTOR SHALL TAKE CARE WHEN INSTALLING UNIT DUCT TO AVOID CONFLICTS WITH EXISTING UNDERGROUND UTILITIES AND TREE'S ROOTS. THE CONTRACTOR SHALL BE RESPONSIBLE FOR ANY DAMAGE AS DETERMINED BY THE ENGINEER.
10.

THE CONTRACTOR SHALL TAKE CARE WHEN INSTALLING LIGHT POLE FOUNDATIONS TO AVOID CONFLICTS WITH UNDERGROUND UTILITIES. WHEN CONFLICTS ARE ENCOUNTERED, THE CONTRACTOR SHALL SUGGEST TO RELOCATE THE FOUNDATIONS. THE NEW LOCATION SHALL BE APPROVED BY THE ENGINEER PRIOR TO INSTALLATION.
11.

GROUND RODS SHALL BE INSTALLED AT EACH LIGHTING UNIT, CONTROLLER CABINET, AND SERVICE INSTALLATION. WHERE BREAKAWAY BASES ARE SPECIFIED, THE BASE AND THE POLE SHALL BE APPROPRIATELY GROUNDED.
12.

LUMINAIRE SAFETY CABLE SHALL BE INSTALLED FOR EACH PROPOSED LUMINAIRE SPECIFIED FOR INSTALLATION ON THIS PROJECT PER BE-701 OR AS DIRECTED BY ENGINEER.
13.

THE CONTRACTOR IS RESPONSIBLE FOR OPERATION AND MAINTENANCE OF TEMPORARY LIGHTING SYSTEM AND SHALL ENSURE CONTINUOUS OPERATION DURING NIGHT-TIME HOURS.
14.

IDOT ELECTRICAL MAINTENANCE SHOULD BE NOTIFIED AT LEAST 14 DAYS BEFORE TRANSFERRING THE EXISTING LIGHTING SYSTEM TO THE CONTRACTOR. CONTACT LONG TRAN FROM IDOT LIGHTING MAINTENANCE TRANSFER: LONG.TRAN@ILLINOIS.GOV (847) 705-4232.
15.

THE CONTRACTOR SHALL VERIFY THE LOCATIONS OF ALL UNDERGROUND UTILITIES BEFORE TRENCHING AND AUGURING.
16.

ALL AERIAL CABLE SHALL MAINTAIN A MINIMUM VERTICAL CLEARANCE OF 18 FEET.
17.

THE TEMPORARY LIGHTING SHALL BE INSTALLED AND OPERATIONAL BEFORE THE EXISTING LIGHT POLES ARE RELOCATED AND STORED. THE PROPOSED LIGHT POLES SHALL BE INSTALLED AND OPERATIONAL BEFORE THE TEMPORARY LIGHTING IS REMOVED.
18.

WHEN REMOVED, THE EXISTING LIGHTING CONTROLLER SHALL BE SALVAGED FOR THE ILLINOIS DEPARTMENT OF TRANSPORTATION.

BILL OF MATERIALS

DESCRIPTION	UNIT	QUANTITY
ELECTRIC SERVICE INSTALLATION	EACH	1
ELECTRIC UTILITY SERVICE CONNECTION	L SUM	1
UNDERGROUND CONDUIT, GALVANIZED STEEL, 4" DIA.	FOOT	745
UNIT DUCT, 600V, 3-1C NO.6, 1/C NO.8 GROUND, (XLP-TYPE USE), 1 1/4" DIA. POLYETHYLENE	FOOT	6400
ELECTRIC CABLE IN CONDUIT, 600V (XLP-TYPE USE) 1/C NO. 10	FOOT	1208
ELECTRIC CABLE IN CONDUIT, 600V (XLP-TYPE USE) 1/C NO. 1/0	FOOT	150
AERIAL CABLE, 3-1/C NO. 6 WITH MESSENGER WIRE	FOOT	4660
LUMINAIRE, LED, ROADWAY, OUTPUT DESIGNATION I	EACH	28
LIGHTING CONTROLLER, BASE MOUNTED, 480VOLT, 100AMP	EACH	1
LIGHT POLE, ALUMINUM, 47.5 FT. M.H., 15 FT. MAST ARM	EACH	24
LIGHT POLE, WOOD, 60 FOOT, CLASS 4, WITH 15FT MAST ARM	EACH	18
LIGHT POLE FOUNDATION, METAL, 15" BOLT CIRCLE, 10" X 8'	EACH	24
BREAKAWAY DEVICE, TRANSFORMER BASE, 15 INCH BOLT CIRCLE	EACH	24
REMOVAL OF TEMPORARY LIGHTING UNIT	EACH	18
REMOVAL OF LIGHTING UNIT, SALVAGE	EACH	20
REMOVAL OF POLE FOUNDATION	EACH	20
REMOVAL OF LIGHTING CONTROLLER	EACH	1
REMOVAL OF LIGHTING CONTROLLER FOUNDATION	EACH	1
MAINTENANCE OF LIGHTING SYSTEM	CAL MO	12
TEMPORARY LUMINAIRE, LED, ROADWAY, OUTPUT DESIGNATION I	EACH	18
COMBINATION LIGHTING CONTROLLER	EACH	1
TEMPORARY WOOD POLE, 60 FT., CLASS 4	EACH	4
LUMINAIRE SAFETY CABLE ASSEMBLY	EACH	28


LEGEND

	EXISTING LIGHTING UNIT TO BE REMOVED AND SALVAGED
	EXISTING LIGHTING UNIT TO REMAIN AS PART OF TEMPORARY LIGHTING AND BE REMOVED AND SALVAGED WHEN TEMPORARY LIGHTING IS REMOVED.
	TEMPORARY WOOD POLE, 50 FT. MH, 15 FT. MAST ARM WITH 240VAC LED LUMINAIRE, OUTPUT DESIGNATION I
	PROPOSED LIGHTING UNIT, 47.5 FT. MH, 15 FT. MAST ARM, WITH 240VAC LED LUMINAIRE, OUTPUT DESIGNATION I ON METAL FOUNDATION WITH BREAKAWAY DEVICE
	TEMPORARY WOOD POLE, 60 FT., CLASS 4
	EXISTING IDOT LIGHTING CONTROLLER "KT", SALVAGED
	PROPOSED IDOT LIGHTING CONTROLLER "KT" 240/480V, SINGLE PHASE, 3 WIRE, 100AMP
	EXISTING ELECTRIC SERVICE
	PROPOSED ELECTRIC SERVICE 240/480V, SINGLE PHASE, 3WIRE
	UNIT DUCT, 600V, 3-1C NO.6 1/C NO.8 GROUND, (XLP-TYPE USE), 1½" DIA. POLYETHYLENE
	EXISTING UNIT DUCT TO BE REMOVED
	UNDERGROUND CONDUIT GALVANIZED STEEL, 4" DIA. WITH UNIT DUCT
	ELECTRICAL CABLE IN CONDUIT 3-1/C NO. 1/0
	GROUND ROD
	AERIAL CABLE, 3-1/C NO.6 WITH MESSENGER WIRE

USER NAME = modeltche	DESIGNED - MH	REVISED -
	DRAWN - SR	REVISED -
PLOT SCALE = 100,0000' / in.	CHECKED - BL	REVISED -
PLOT DATE = 7/11/2025	DATE - 02-12-2025	REVISED -

F.A. RTE.	SECTION	COUNTY	TOTAL SHEETS	SHEET NO.
	19-00514-00-WR	KANE	304	198
		CONTRACT NO. 61L28		
		ILLINOIS	FED. AID PROJECT	

	EXISTING LIGHTING UNIT TO BE REMOVED AND SALVAGED
	EXISTING LIGHTING UNIT TO REMAIN AS PART OF TEMPORARY LIGHTING AND BE REMOVED AND SALVAGED WHEN TEMPORARY LIGHTING IS REMOVED.
	TEMPORARY WOOD POLE, 50 FT. MH, 15 FT. MAST ARM WITH 240VAC LED LUMINAIRE, OUTPUT DESIGNATION I
	PROPOSED LIGHTING UNIT, 47.5 FT. MH, 15 FT. MAST ARM, WITH 240VAC LED LUMINAIRE, OUTPUT DESIGNATION I ON METAL FOUNDATION WITH BREAKAWAY DEVICE
	TEMPORARY WOOD POLE, 60 FT., CLASS 4
	EXISTING IDOT LIGHTING CONTROLLER "KT", SALVAGED
	PROPOSED IDOT LIGHTING CONTROLLER "KT" 240/480V, SINGLE PHASE, 3 WIRE, 100AMP
	EXISTING ELECTRIC SERVICE
	PROPOSED ELECTRIC SERVICE 240/480V, SINGLE PHASE, 3WIRE
	UNIT DUCT, 600V, 3-1C NO.6 1/C NO.8 GROUND, (XLP-TYPE USE), 1½" DIA. POLYETHYLENE
	EXISTING UNIT DUCT TO BE REMOVED
	UNDERGROUND CONDUIT GALVANIZED STEEL, 4" DIA. WITH UNIT DUCT
	ELECTRICAL CABLE IN CONDUIT 3-1/C NO. 1/0
	GROUND ROD
	AERIAL CABLE, 3-1/C NO.6 WITH MESSENGER WIRE

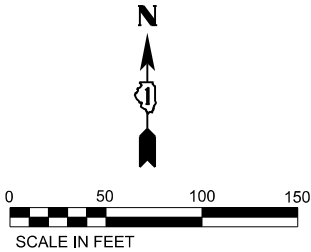

1. FOR GENERAL NOTES AND LEGEND, SEE SHEET LT-01.
2. THE TEMPORARY LIGHTING UNITS SHALL BE FED FROM THE EXISTING LIGHTING SYSTEM/CONTROLLER.
3. THE EXISTING LIGHTING UNITS TO BE REMOVED SHALL BE REMOVED WHEN THE TEMPORARY LIGHTING IS INSTALLED AND FULLY OPERATIONAL.
4. THE TEMPORARY LIGHTING SHALL BE REMOVED WHEN PROPOSED LIGHTING IS FULLY INSTALLED AND IS OPERATIONAL.
5. EXISTING UNIT DUCT TO REMAIN AS PART OF TEMPORARY LIGHTING AND BE REMOVED WHEN TEMPORARY LIGHTING IS REMOVED.

USER NAME = mdeltshe	DESIGNED - MH	REVISED -
	DRAWN - SR	REVISED -
PLOT SCALE = 100.000' / in.	CHECKED - BL	REVISED -
PLOT DATE = 7/11/2025	DATE - 02-12-2025	REVISED -

REMOVAL/TEMPORARY LIGHTING PLAN RANDALL ROAD AT IL-72

SCALE:	SHEET	OF	SHEETS	STA.	TO STA.
--------	-------	----	--------	------	---------

F.A. RTE.	SECTION	COUNTY	TOTAL SHEETS	SHEET NO.
	19-00514-00-WR	KANE	304	199
		CONTRACT NO. 61L28		
		ILLINOIS	FED. AID PROJECT	

LEGEND

- 

EXISTING LIGHTING UNIT TO BE REMOVED AND SALVAGED
- 

EXISTING LIGHTING UNIT TO REMAIN AS PART OF TEMPORARY LIGHTING AND BE REMOVED AND SALVAGED WHEN TEMPORARY LIGHTING IS REMOVED.
- 

TEMPORARY WOOD POLE, 50 FT. MH, 15 FT. MAST ARM WITH 240VAC LED LUMINAIRE, OUTPUT DESIGNATION I
- 

PROPOSED LIGHTING UNIT, 47.5 FT. MH, 15 FT. MAST ARM, WITH 240VAC LED LUMINAIRE, OUTPUT DESIGNATION I ON METAL FOUNDATION WITH BREAKAWAY DEVICE
- 

TEMPORARY WOOD POLE, 60 FT., CLASS 4
- 

EXISTING IDOT LIGHTING CONTROLLER "KT", SALVAGED
- 

PROPOSED IDOT LIGHTING CONTROLLER "KT" 240/480V, SINGLE PHASE, 3 WIRE, 100AMP
- 

EXISTING ELECTRIC SERVICE
- 

PROPOSED ELECTRIC SERVICE 240/480V, SINGLE PHASE, 3WIRE
- 

UNIT DUCT, 600V, 3-1C NO.6 1/C NO.8 GROUND, (XLP-TYPE USE), 1½" DIA. POLYETHYLENE
- 



EXISTING UNIT DUCT TO BE REMOVED
- 

UNDERGROUND CONDUIT GALVANIZED STEEL, 4" DIA. WITH UNIT DUCT
- 

ELECTRICAL CABLE IN CONDUIT 3-1/C NO. 1/0
- 

GROUND ROD
- 

AERIAL CABLE, 3-1/C NO.6 WITH MESSENGER WIRE

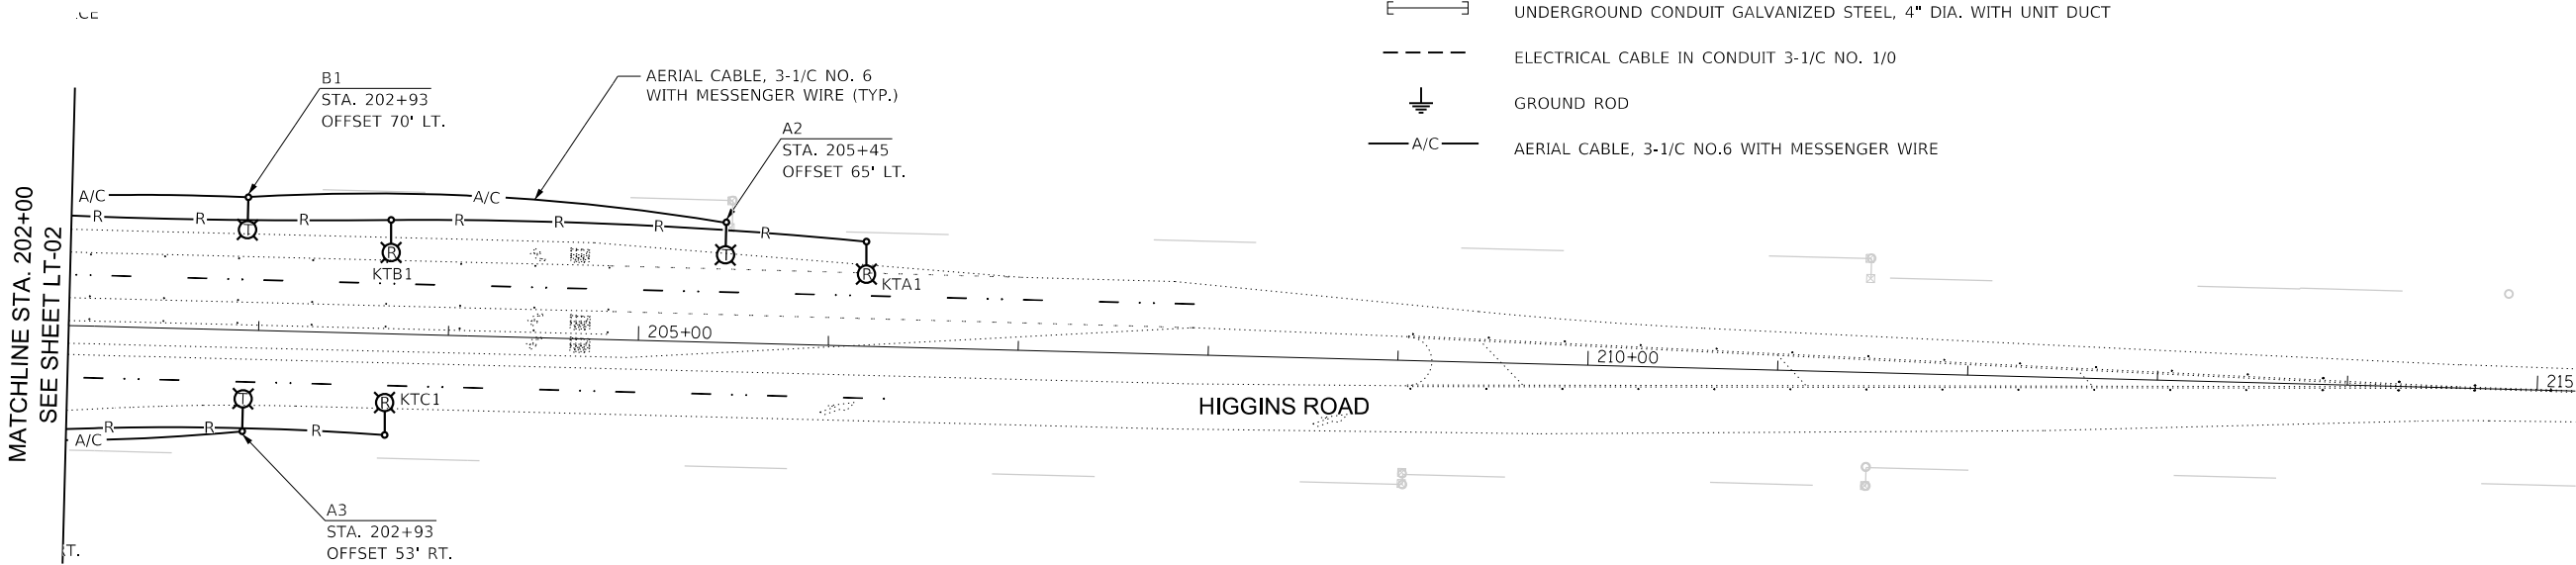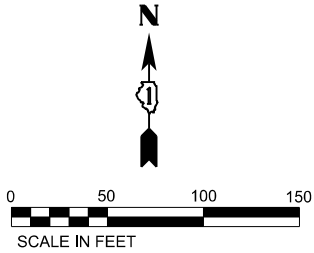

NOTES:

1. FOR GENERAL NOTES AND LEGEND, SEE SHEET LT-01.
2. THE TEMPORARY LIGHTING UNITS SHALL BE FED FROM THE EXISTING LIGHTING SYSTEM.
3. THE EXISTING LIGHTING UNITS TO BE REMOVED SHALL BE REMOVED WHEN THE TEMPORARY LIGHTING IS INSTALLED AND FULLY OPERATIONAL.
4. THE TEMPORARY LIGHTING SHALL BE REMOVED WHEN PROPOSED LIGHTING IS FULLY INSTALLED AND IS OPERATIONAL.

LT-03



AMES Engineering, Inc.
CONSULTING ENGINEERS
6330 Belmont Road, Suite 4B
Downers Grove, IL 60816

USER NAME = modeltche	DESIGNED - MH	REVISED -
	DRAWN - SR	REVISED -
	CHECKED - BL	REVISED -
	DATE - 02-12-2025	REVISED -
PLOT SCALE = 100,000' / 1in.		
PLOT DATE = 7/11/2025		

STATE OF ILLINOIS
DEPARTMENT OF TRANSPORTATION

REMOVAL/TEMPORARY LIGHTING PLAN
RANDALL ROAD AT IL-72

SCALE: SHEET OF SHEETS STA. TO STA.

F.A. RTE.	SECTION	COUNTY	TOTAL SHEETS	SHEET NO.
	19-00514-00-WR	KANE	304	200
CONTRACT NO. 61L28				
ILLINOIS FED. AID PROJECT				